

COLUMBIA STORM PROCESSING & SERVICE CENTER - BUILDING D - TRUCK WASH

1855 NW COUNTY ROAD 25A, LAKE CITY, FL
CONSTRUCTION DOCUMENTS - 02/25/2026

SHEET INDEX

Sheet Number	Sheet Name
00 - COVER SHEET	
D-G000	COVER SHEET
01 - GENERAL/LIFE SAFETY	
D-G001	ABBREVIATIONS, SYMBOLS, GENERAL NOTES
D-G002	BUILDING DATA AND CODE SUMMARY
D-G111	LIFE SAFETY
D-G121	PARTITION TYPES AND DETAILS
D-G122	UL ASSEMBLY INFORMATION
D-G123	UL ASSEMBLY INFORMATION
D-G124	UL ASSEMBLY INFORMATION
04 - ARCHITECTURE	
D-A101	ARCHITECTURAL SITE PLAN
D-A111	FLOOR, ROOF, FINISH AND SIGNAGE, AND CEILING PLANS
D-A211	EXTERIOR ELEVATIONS
D-A311	BUILDING AND WALL SECTIONS
D-A400	TYPICAL MOUNTING DETAILS
D-A501	EXTERIOR DETAILS
D-A512	ROOF DETAILS
D-A513	ROOF DETAILS
D-A521	SITE DETAILS
D-A601	SIGNAGE DETAILS
D-A701	INTERIOR DETAILS
D-A711	CEILING DETAILS
D-A800	EQUIPMENT SCHEDULE AND FINISH SCHEDULE
D-A900	DOOR SCHEDULE, OPENING TYPES, AND HARDWARE SETS
D-A901	OPENING DETAILS
05 - STRUCTURAL	
D-S001	GENERAL NOTES
D-S002	GENERAL NOTES
D-S003	GENERAL SCHEDULES
D-S004	SPECIAL INSPECTION PLAN
D-S101	FRAMING PLANS
D-S201	FOUNDATION SECTIONS & DETAILS
D-S202	FOUNDATION SECTIONS & DETAILS
D-S301	FRAMING SECTIONS & DETAILS
06 - MECHANICAL	
D-M001	LEGENDS AND INDEX
D-M002	SCHEDULES AND DETAILS
D-M101	FLOOR PLAN
07 - PLUMBING	
D-P001	GENERAL NOTES, GENERAL SPECIFICATIONS, CODES & LEGENDS
D-P002	SCHEDULES AND DETAILS
D-P101	FLOOR PLAN - PRESSURE & GRAVITY PIPING & RISER DIAGRAMS
08 - ELECTRICAL	
D-E001	GENERAL NOTES, GENERAL SPECIFICATIONS, CODES & LEGENDS
D-E002	LIGHT FIXTURE SCHEDULES & CONTROLS
D-EG101	LIGHTNING PROTECTION & GROUNDING PLAN
D-EL101	LIGHTING PLAN
D-EP101	POWER PLAN
D-E601	ELECTRICAL DETAILS, RISER DIAGRAM & PANEL BOARD

LITTLE

DIVERSIFIED ARCHITECTURAL CONSULTING

201 South Orange Ave


Orlando, FL 32801

T: 407.218.8282


www.littleonline.com

This drawing and the design shown are the property of Little Diversified Architectural Consulting. The reproduction, copying, or other use of this drawing without their written consent is prohibited and any infringement will be subject to legal action.


© Little 2026

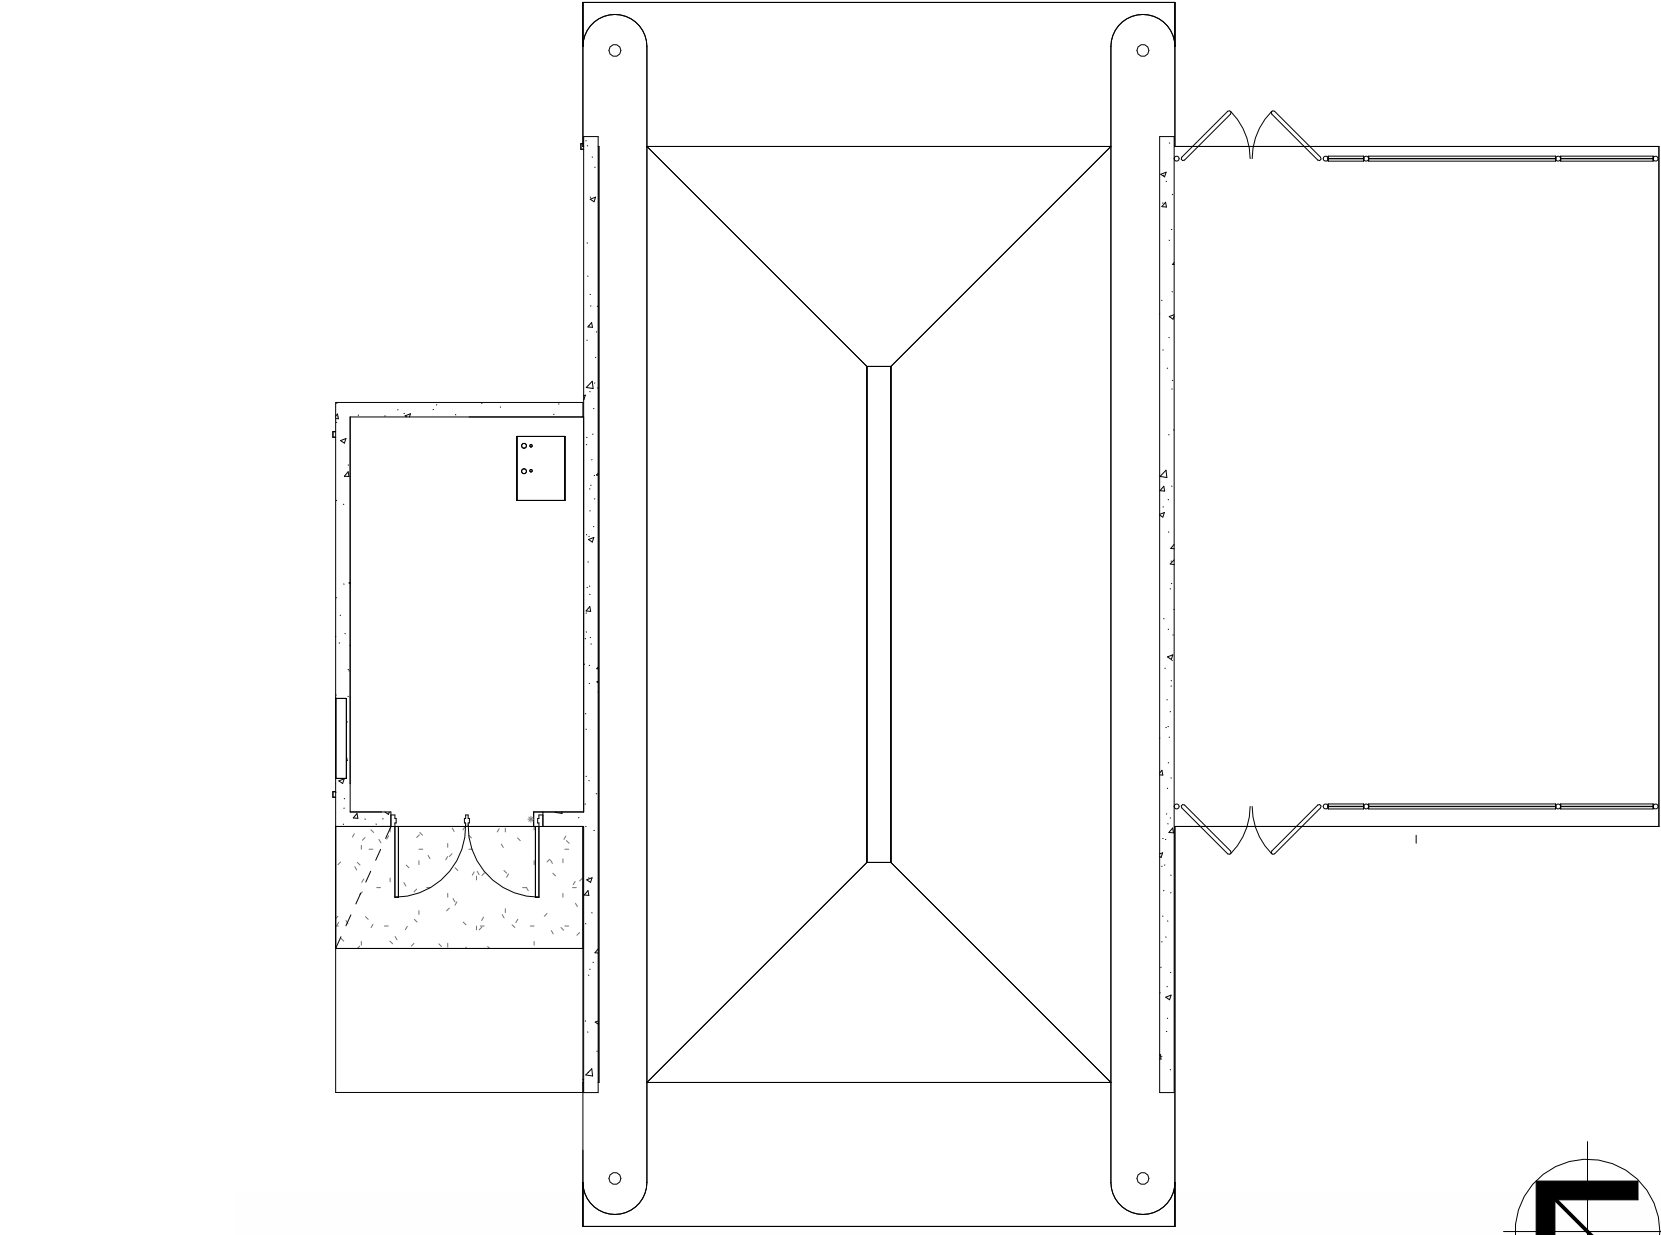

KEY PLAN - BUILDING D

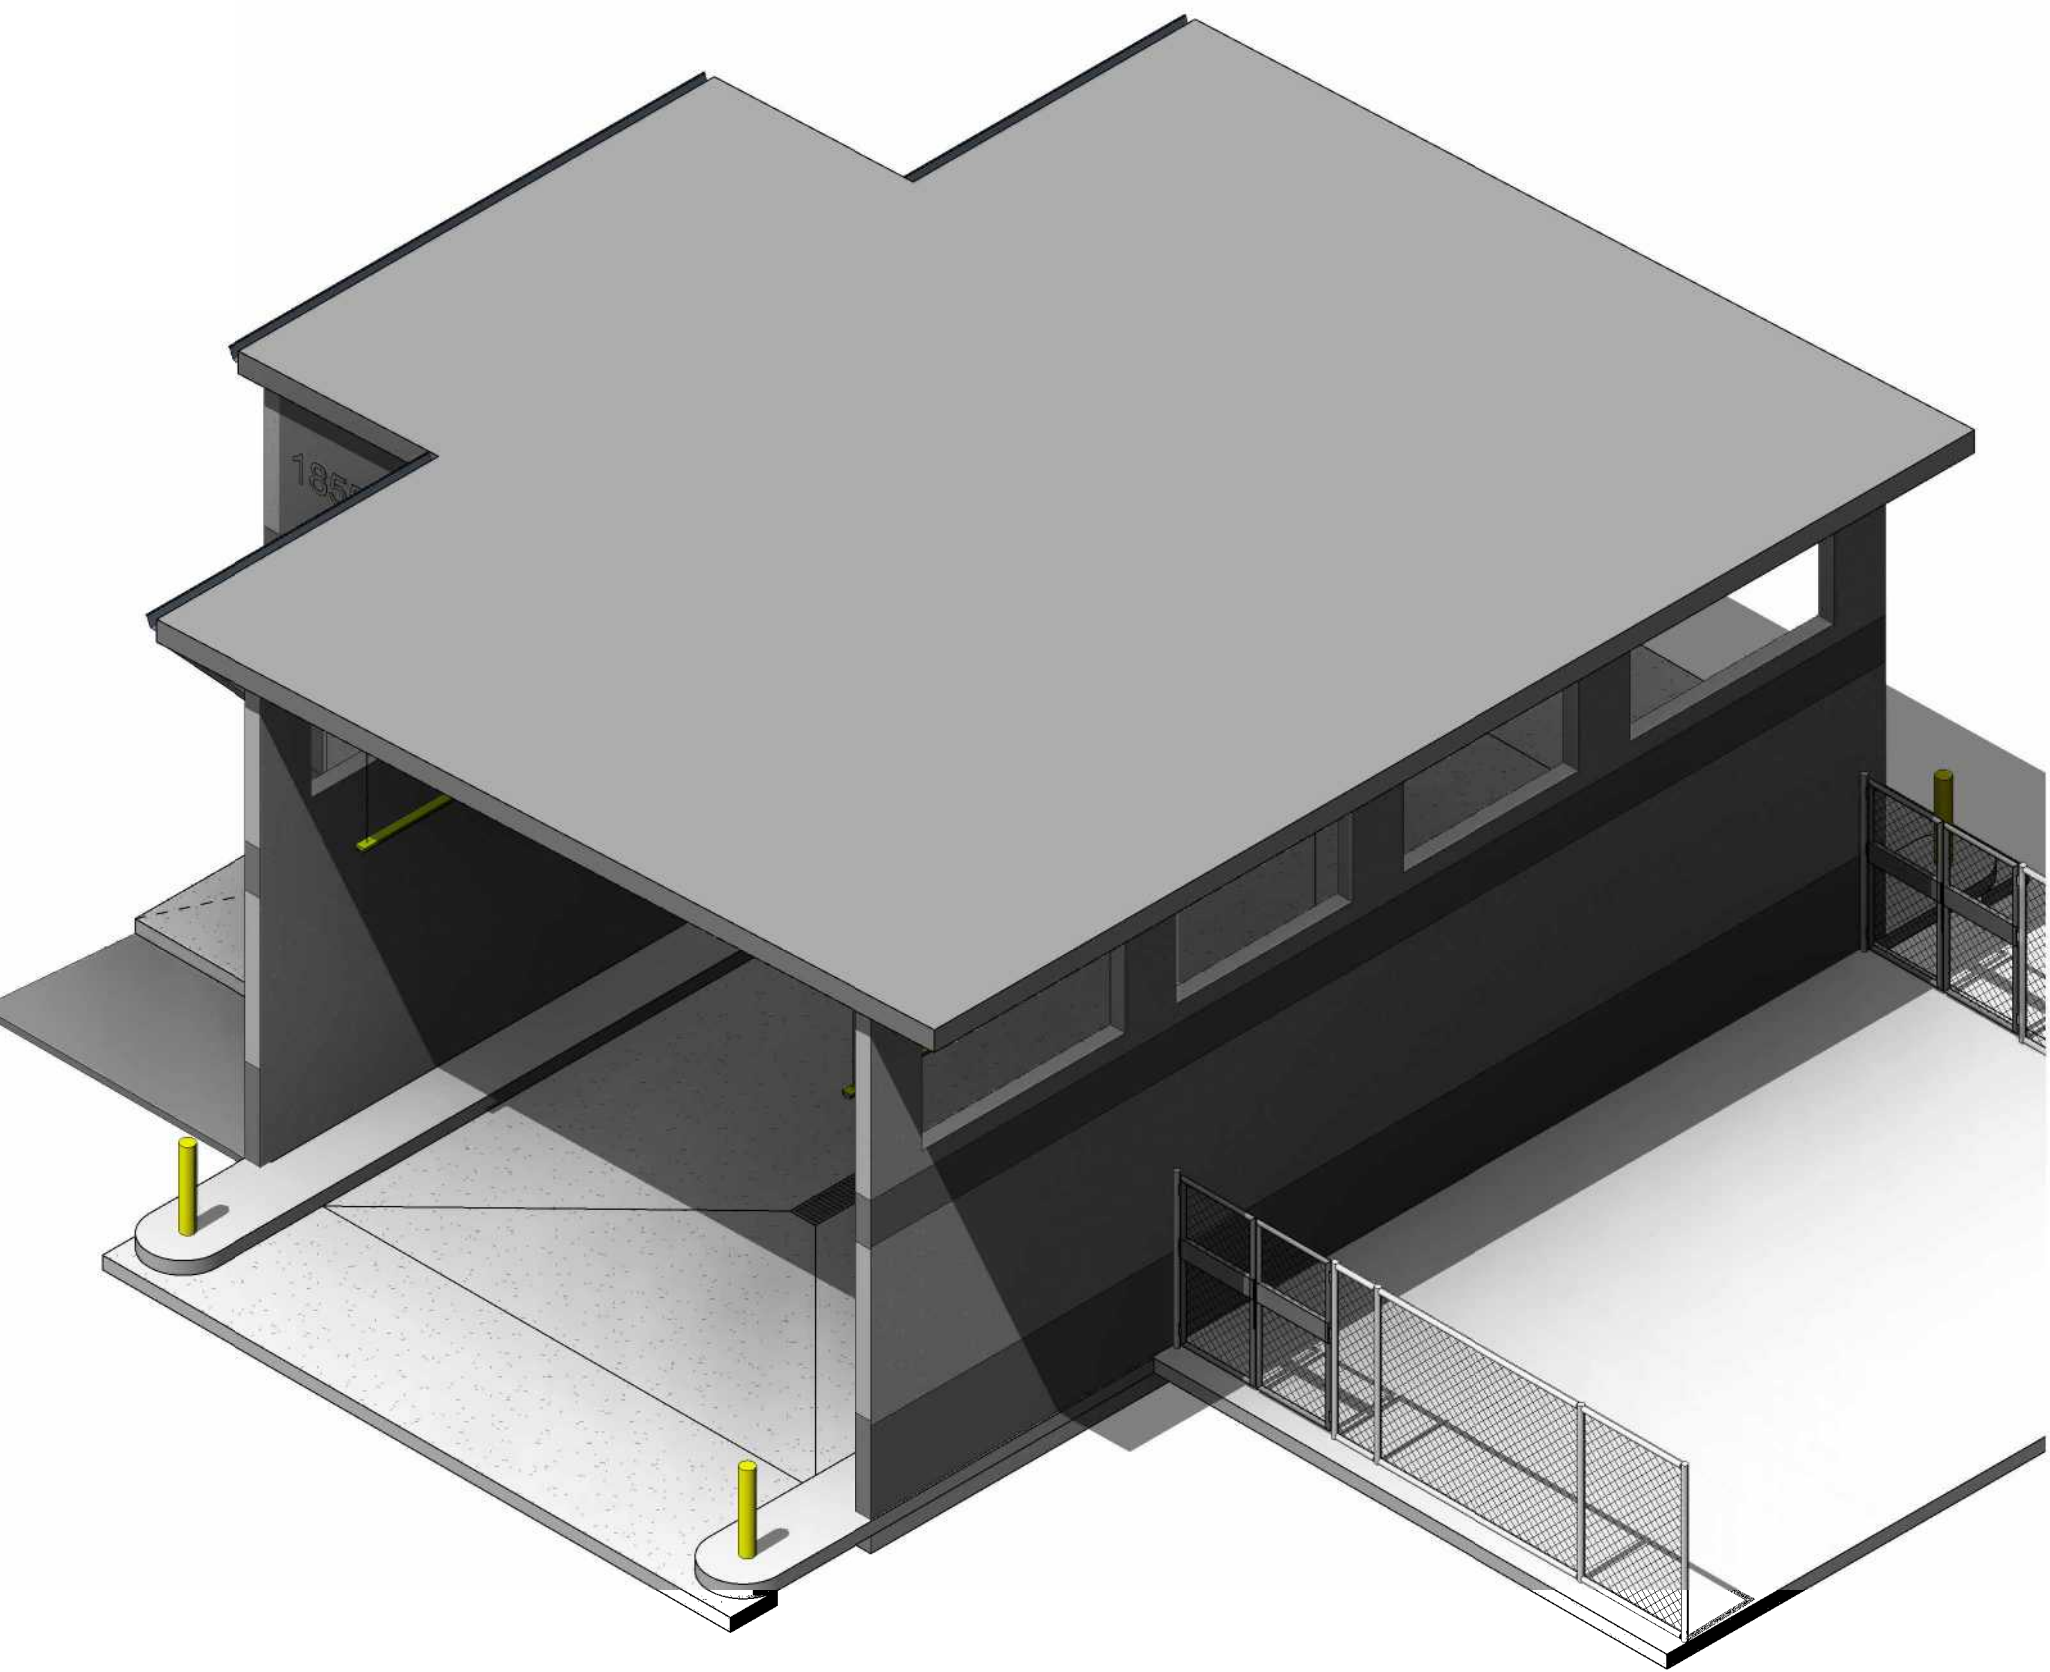


3D VIEW - BUILDING D

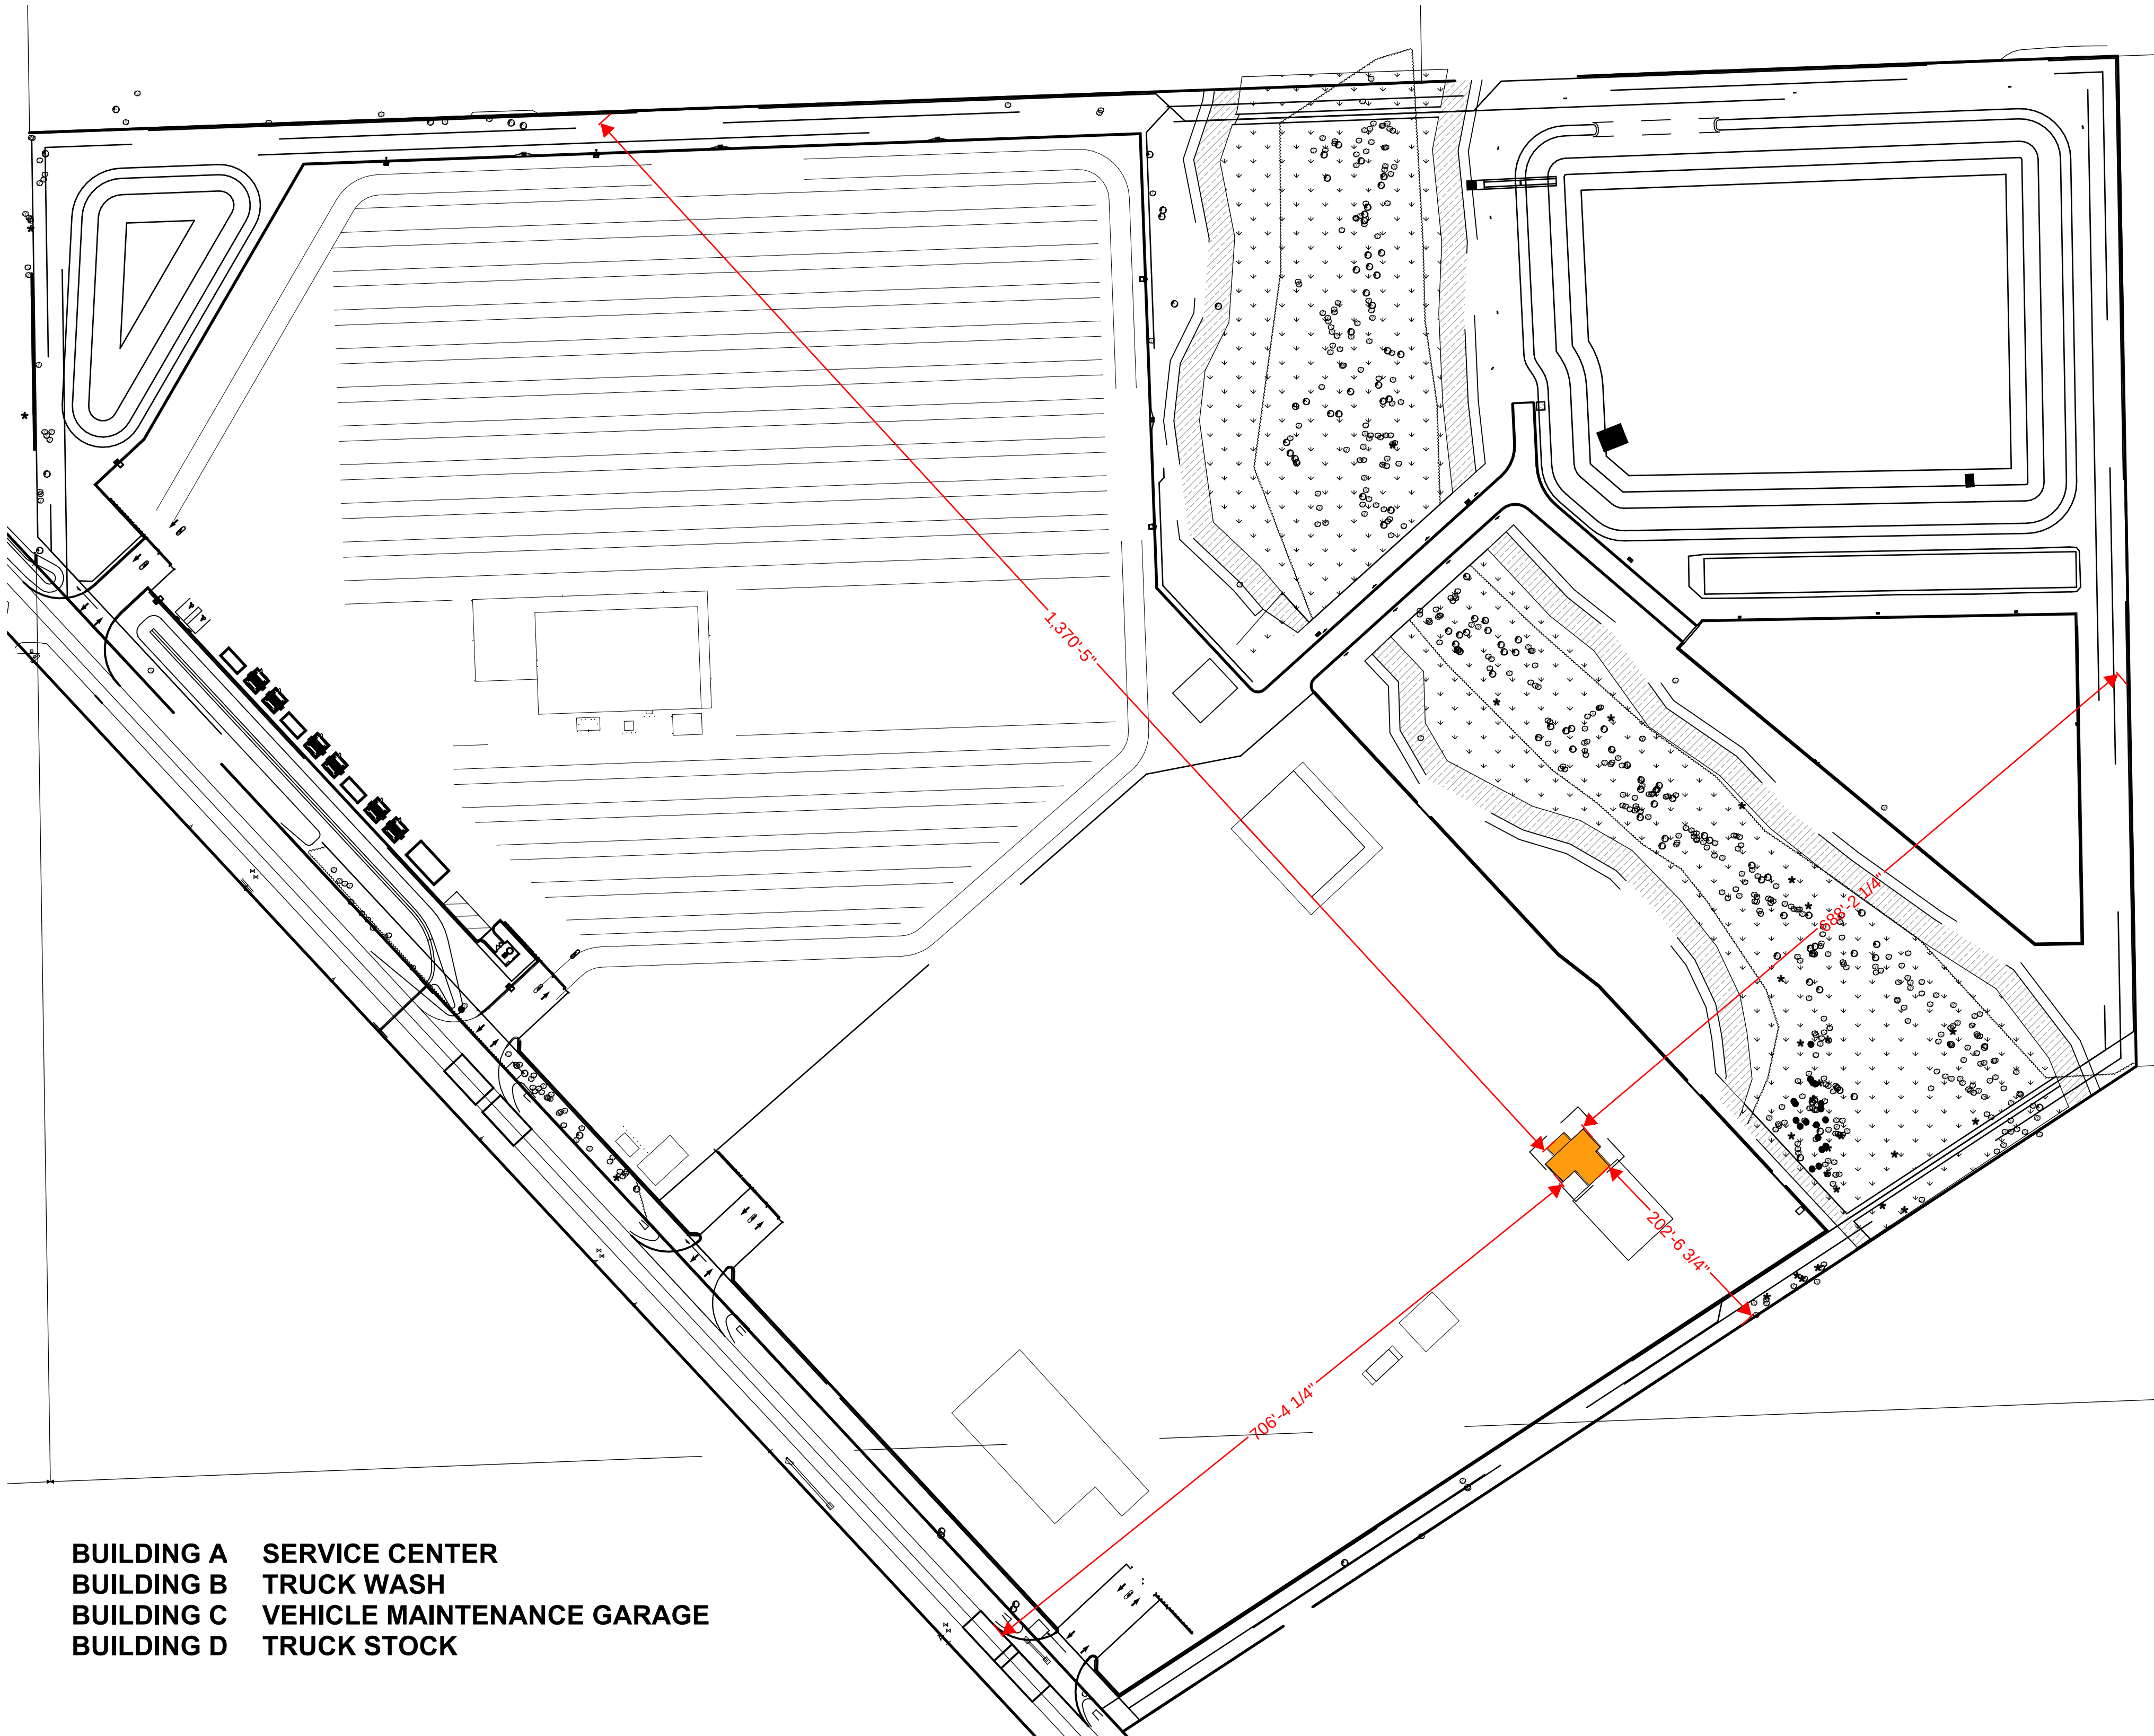

BUILDING A SERVICE CENTER
BUILDING B TRUCK WASH
BUILDING C VEHICLE MAINTENANCE GARAGE
BUILDING D TRUCK STOCK

COVER SHEET PLAN
1" = 100'-0"

NOTE: REFER TO CIVIL DRAWINGS FOR SITE PERMIT DOCUMENTS.

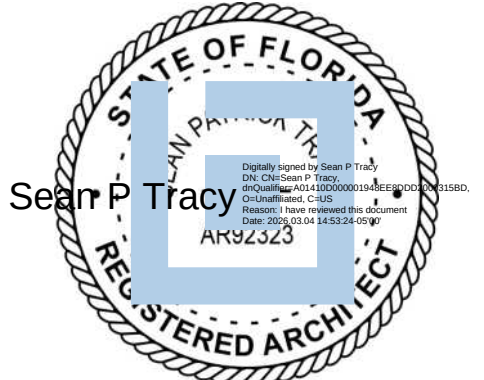

ISSUE FOR
CONSTRUCTION
DOCUMENTS

ISSUE DATE
02/25/2026

REVISIONS
NO. REASON DATE

PROJECT TEAM
PRINCIPAL IN CHARGE
SEAN TRACY
PROJECT MANAGER
BENJAMIN BOYLES
DESIGN TEAM
ORL-COMMUNITY
PROJECT NAME

COLUMBIA STORM
PROCESSING & SERVICE
CENTER - BUILDING D -
TRUCK WASH

PROJECT NO.
814C632800
SHEET TITLE
COVER SHEET

SHEET NUMBER
D-G000

OWNER

FLORIDA POWER & LIGHT COMPANY
1655 S. FERDON BLVD.
CRESTVIEW, FL 32636
(561) 339-5349
JOEL JONES

ARCHITECTURE

LITTLE
201 S. ORANGE AVE. SUITE 800
ORLANDO, FL 32801
(407) 218-8286
SEAN TRACY

CIVIL/LANDSCAPE

KIMLEY HORN
12470 GRAN BAY PARKWAY WEST SUITE
2350
JACKSONVILLE, FL 32258
(904) 828-3919
CHRIS REUTHER

STRUCTURAL

JEZERINAC GROUP
480 HIBISCUS ST. SUITE 107
WEST PALM BEACH, FL 33401
(561) 622-8585
RONALD JEZERINAC

PLUMBING/MECHANICAL
CARDINAL ENGINEERING ASSOCIATES,
INC.
575 NW MERCANTILE PL. SUITE 106
PORT ST. LUCIE, FL 34986
(561) 746-6343
SCOTT RAYNOR

ELECTRICAL
CARDINAL ENGINEERING ASSOCIATES,
INC.
575 NW MERCANTILE PL. SUITE 106
PORT ST. LUCIE, FL 34986
(561) 746-6343
DAVID LITHGOW