



ELECTRICAL LEGEND		
ELECTRICAL	COUNT	SYMBOL
CAN LIGHT 6inch	88	○
LED CEILING LIGHT 1x4	9	▬
AC DISCONNECT	4	⏏
CAT6 OUTLET	12	▽
CEILING OUTLET DUPLEX	5	⊖
OUTLET	72	⊕
SMOKE DETECTOR	8	⦿
SWITCH	10	Ⓢ
SWITCH 3 WAY	2	Ⓢ3
SWITCH 4 WAY	2	Ⓢ4

ELECTRICAL PLAN NOTES:

INSTALLATION SHALL BE PER LATEST NAT'L ELECTRIC CODE.

WIRE ALL APPLIANCES, HVAC UNITS AND OTHER EQUIPMENT PER MANUF. SPECIFICATIONS

CONSULT WITH THE OWNER FOR THE NUMBER OF SEPERATE TELEPHONE LINES TO BE INSTALLED

ALL SMOKE DETECTORS SHALL BE 120v w/ BATTERY BACKUP OF THE PHOTOELECTRIC TYPE, AND SHALL BE INTERLOCKED TOGETHER. INSTALL INSIDE AND NEAR ALL BEDROOMS

TELEPHONE, TELEVISION AND OTHER LOW VOLTAGE DEVICES OR OUTLETS SHALL BE AS PER THE OWNER'S DIRECTIONS, & IN ACCORDANCE W/ APPLICABLE SECTIONS OF NEC-LATEST EDITION.


ELECTRICAL CONTR' SHALL PREPARE "AS-BUILT" SHOP DWGS INDICATING ALL ELECTRICAL WORK, INCLUDING ANY CHANGES TO THE ELEC. PLAN, ADDNS TO THE ELEC. PLAN, RISER DIAGRAM, AS-BUILT PANEL SCHEDULE W/ ALL CKTS IDENTIFIED W/ CKT N°. DESCRIPTION & BRKR, SERVICE ENT. & ALL UNDERGROUND WIRE

LOCATIONS/ROUTING / DEPTH, RISER DIA. SHALL INCLUDE WIRE SIZES/TYPE & EQUIPMENT TYPE W/ RATINGS & LOADS.

CONTRACTOR SHALL PROVIDE 1 COPY OF AS-BUILT DWGS TO OWNER & 1 COPY TO THE PERMIT ISSUING AUTHORITY. ALL RECEPTALS NOT OTHERWISE NOTED, SHALL BE ARC FAULT INTERRUPTER TYPE, EXCEPT DEDICATED OUTLETS

ALL RECEPTALS IN WET AREAS SHALL BE GROUND FAULT INTERRUPTER TYPE (GFI)

ALL EXTERIOR RECEPTALS SHALL BE WEATHERPROOF GROUND FAULT INTERRUPTER TYPE (WFGFI)

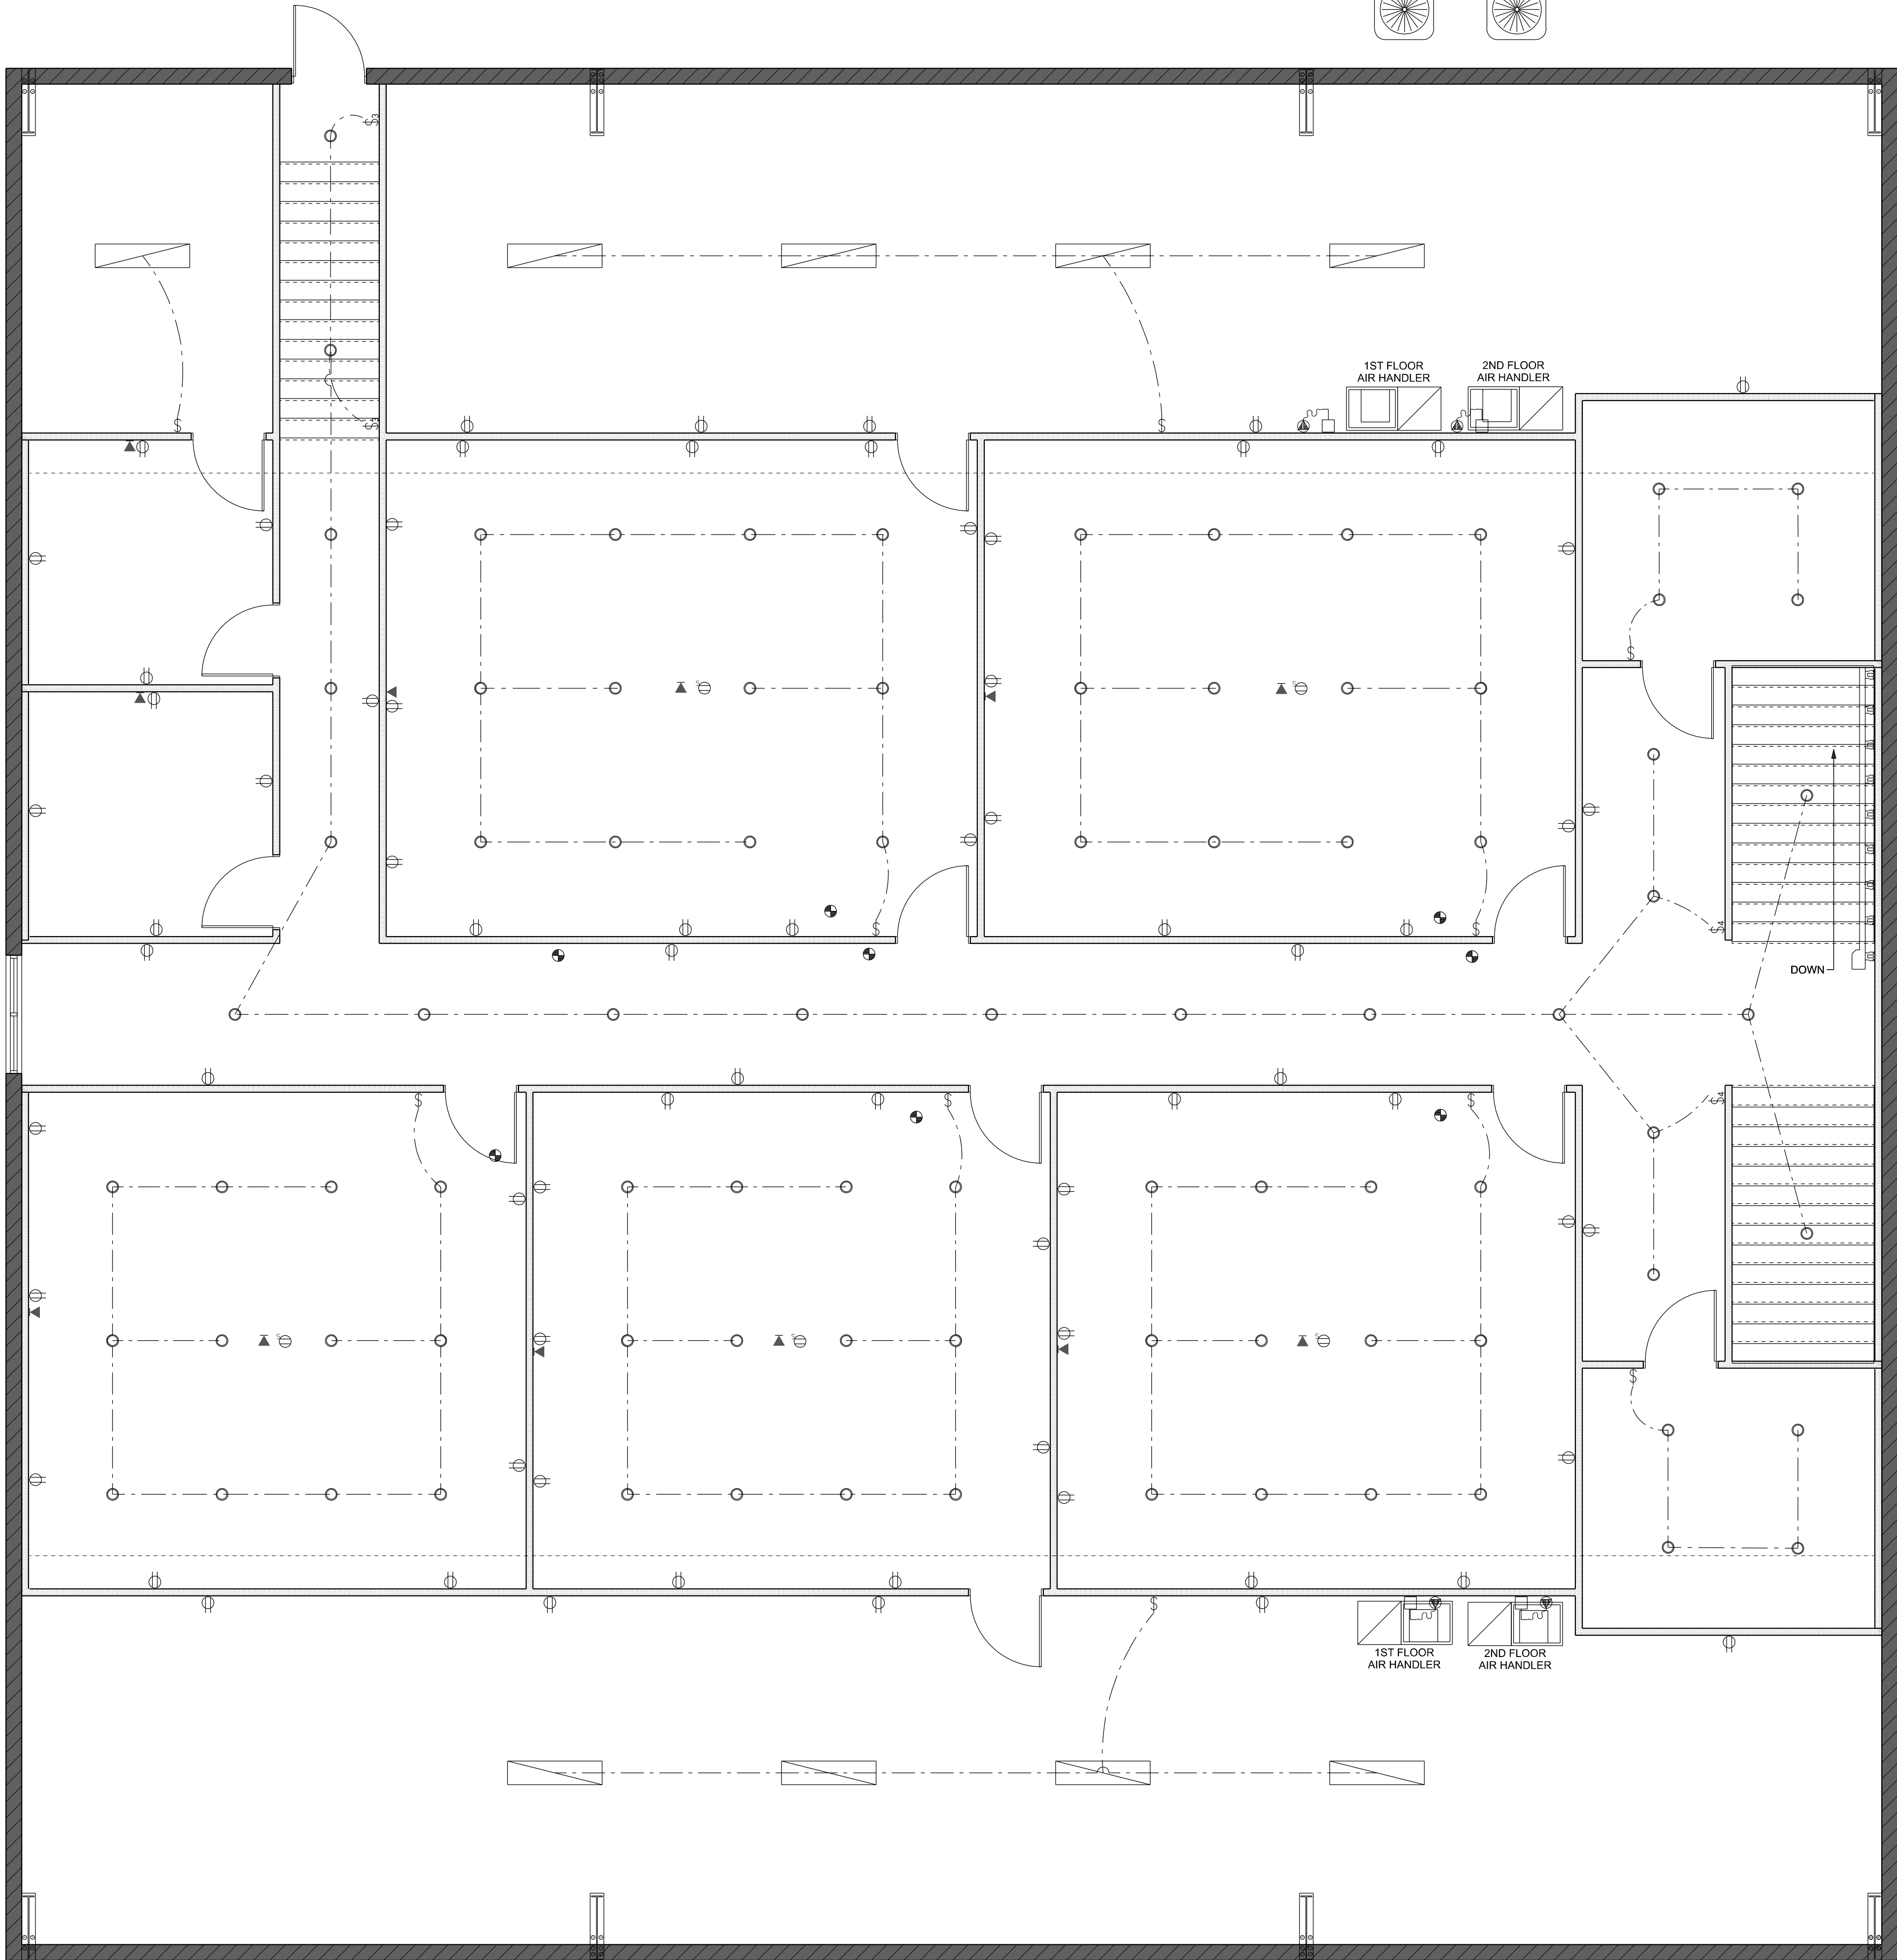

2ND FLOOR ELECTRICAL
SCALE: 1/4" = 1'-0"

REVISIONS SCHEDULE			
PROPOSAL	Jan. 21st, 2026		
PRELIM. CONST.	Feb. 25th, 2026		
REVISED CONST.	Mar. 31st, 2026		

STUDENT LIFE BUILDING RENOVATIONS FOR:
CHRIST CENTRAL
COLUMBIA COUNTY, FL

RIDGEPOINT DESIGN
516 SW ARLINGTON BLVD, STE 103, LAKE CITY, FL 32025
PH: (386) 288 - 1188
E: JON@RIDGEPOINTDESIGN.COM
F: INSTAGRAM.COM/RIDGEPOINTDESIGN

NE
NICHOLAS PAUL
GEISLER ARCHITECT
N.C.A.R.B. Certified

Digitally signed
by Nicholas P Geisler
Date: 2026.06.16 11:59:52 -04'00'

SHEET NUMBER
A.7
OF 12 SHEETS