

COLUMBIA STORM PROCESSING & SERVICE CENTER - BUILDING C - VEHICLE MAINTENANCE GARAGE

1855 NW COUNTY ROAD 25A, LAKE CITY, FL 32055
CONSTRUCTION DOCUMENTS - 02.25.2026

SHEET INDEX

Sheet Number	Sheet Name
00 - COVER SHEET	COVER SHEET
C-G000	
01 - GENERAL/LIFE SAFETY	
C-G001	ABBREVIATIONS, SYMBOLS, GENERAL NOTES
C-G002	BUILDING DATA & CODE SUMMARY
C-G111	LIFE SAFETY
C-G121	PARTITION TYPES AND DETAILS
C-G122	UL ASSEMBLY INFORMATION
C-G123	UL ASSEMBLY INFORMATION
C-G124	UL ASSEMBLY INFORMATION
04 - ARCHITECTURE	
C-A101	ARCHITECTURAL SITE PLAN
C-A111	FLOOR, CEILING, AND FINISH PLANS
C-A112	ROOF PLAN
C-A211	EXTERIOR ELEVATIONS
C-A301	BUILDING SECTIONS
C-A311	WALL SECTIONS
C-A400	TYPICAL MOUNTING DETAILS
C-A401	ENLARGED PLANS AND INTERIOR ELEVATIONS
C-A501	EXTERIOR DETAILS
C-A512	ROOF DETAILS
C-A513	ROOF DETAILS
C-A521	SITE DETAILS
C-A501	SIGNAGE DETAILS
C-A701	INTERIOR DETAILS
C-A711	CEILING DETAILS
C-A721	MILLWORK DETAILS
C-A731	STAIR AND LADDER DETAILS
C-A800	FINISH, SIGNAGE, AND EQUIPMENT SCHEDULES
C-A900	DOOR SCHEDULE, OPENING TYPES, AND HARDWARE SETS
C-A901	OPENING DETAILS

05 - STRUCTURAL	GENERAL NOTES
C-S001	GENERAL NOTES
C-S002	GENERAL SCHEDULES
C-S003	SPECIAL INSPECTION PLAN
C-S101	FOUNDATION PLAN
C-S102	ROOF FRAMING PLAN
C-S201	FOUNDATION SECTIONS & DETAILS
C-S202	FOUNDATION SECTIONS & DETAILS
C-S301	FRAMING SECTIONS & DETAILS
C-S302	FRAMING SECTIONS & DETAILS
C-S303	FRAMING SECTIONS & DETAILS

06 - MECHANICAL	LEGENDS AND INDEX
C-M001	SCHEDULES
C-M002	DETAILS
C-M003	SPECIFICATIONS
C-M004	DETAILS
C-M005	CONTROLS
C-M101	FIRST FLOOR PLAN


07 - PLUMBING	GENERAL NOTES, GENERAL SPECIFICATIONS, CODES & LEGENDS
C-P001	SCHEDULES & DETAILS
C-P002	DETAILS
C-P003	SPECIFICATION
C-P101	FLOOR PLAN - GRAVITY PIPING
C-P102	FLOOR PLAN - PRESSURE PIPING
C-P201	RISER DIAGRAMS

08 - ELECTRICAL	GENERAL NOTES, GENERAL SPECIFICATIONS, CODES & LEGENDS
C-E001	LIGHT FIXTURE SCHEDULE
C-E002	LIGHTING CONTROLS
C-E003	ELECTRICAL SITE PLAN
C-EG101	LIGHTNING PROTECTION & GROUNDING PLAN
C-EL101	PHOTOMETRIC PLAN
C-EL102	LIGHTING CONTROLS PLAN
C-EL103	LIGHTING PLAN
C-EP101	POWER PLAN
C-E501	DETAILS
C-E502	GROUNDING & LIGHTNING PROTECTION DETAILS
C-E503	DETAILS
C-E504	DETAILS
C-E505	DETAILS
C-E506	DETAILS
C-E601	ONE LINE DIAGRAM
C-E701	PANELBOARD SCHEDULES
C-T101	SYSTEM PLAN
C-FA101	FIRE ALARM NOTES & GROUND FLOOR DEVICE LAYOUT
C-FA501	FIRE ALARM TYPICAL RISER DIAGRAM, SEQUENCE OF OPERATIONS & DEVICE DETAILS



201 South Orange Ave
Orlando, FL 32801
T: 407.218.8282
www.littleonline.com

This drawing and the design shown are the property of Little Diversified Architectural Consulting. The reproduction, copying, or other use of this drawing without their written consent is prohibited and any infringement will be subject to legal action.
© Little 2026

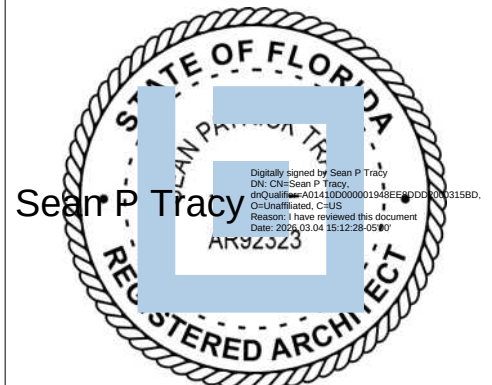

ISSUE FOR
CONSTRUCTION DOCUMENTS

ISSUE DATE
02.25.2026

REVISIONS


NO.	REASON	DATE
-----	--------	------

PROJECT TEAM
PRINCIPAL IN CHARGE
SEAN TRACY
PROJECT MANAGER
BENJAMIN BOYLES
DESIGN TEAM
ORL-COMMUNITY


COLUMBIA STORM
PROCESSING & SERVICE
CENTER - BUILDING C
VEHICLE MAINTENANCE
GARAGE

PROJECT NO.
814C632800
SHEET TITLE
COVER SHEET


SHEET NUMBER
C-G000

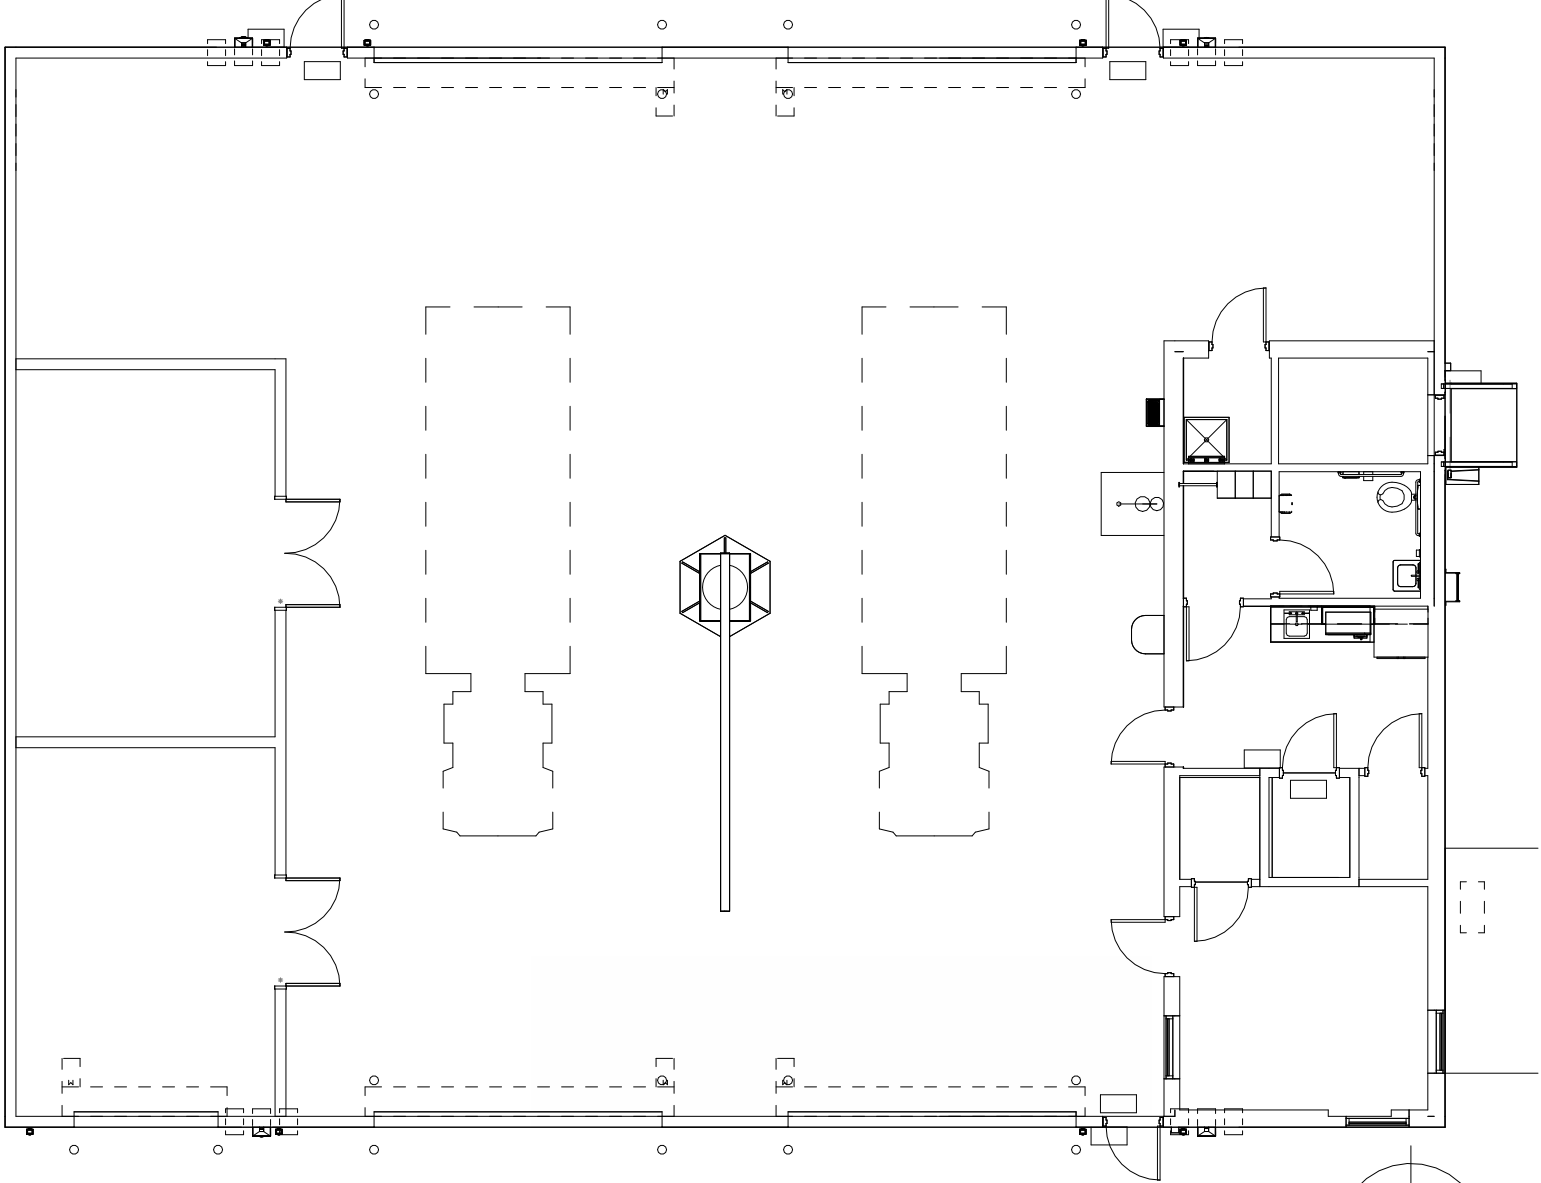

KEY PLAN - BUILDING C

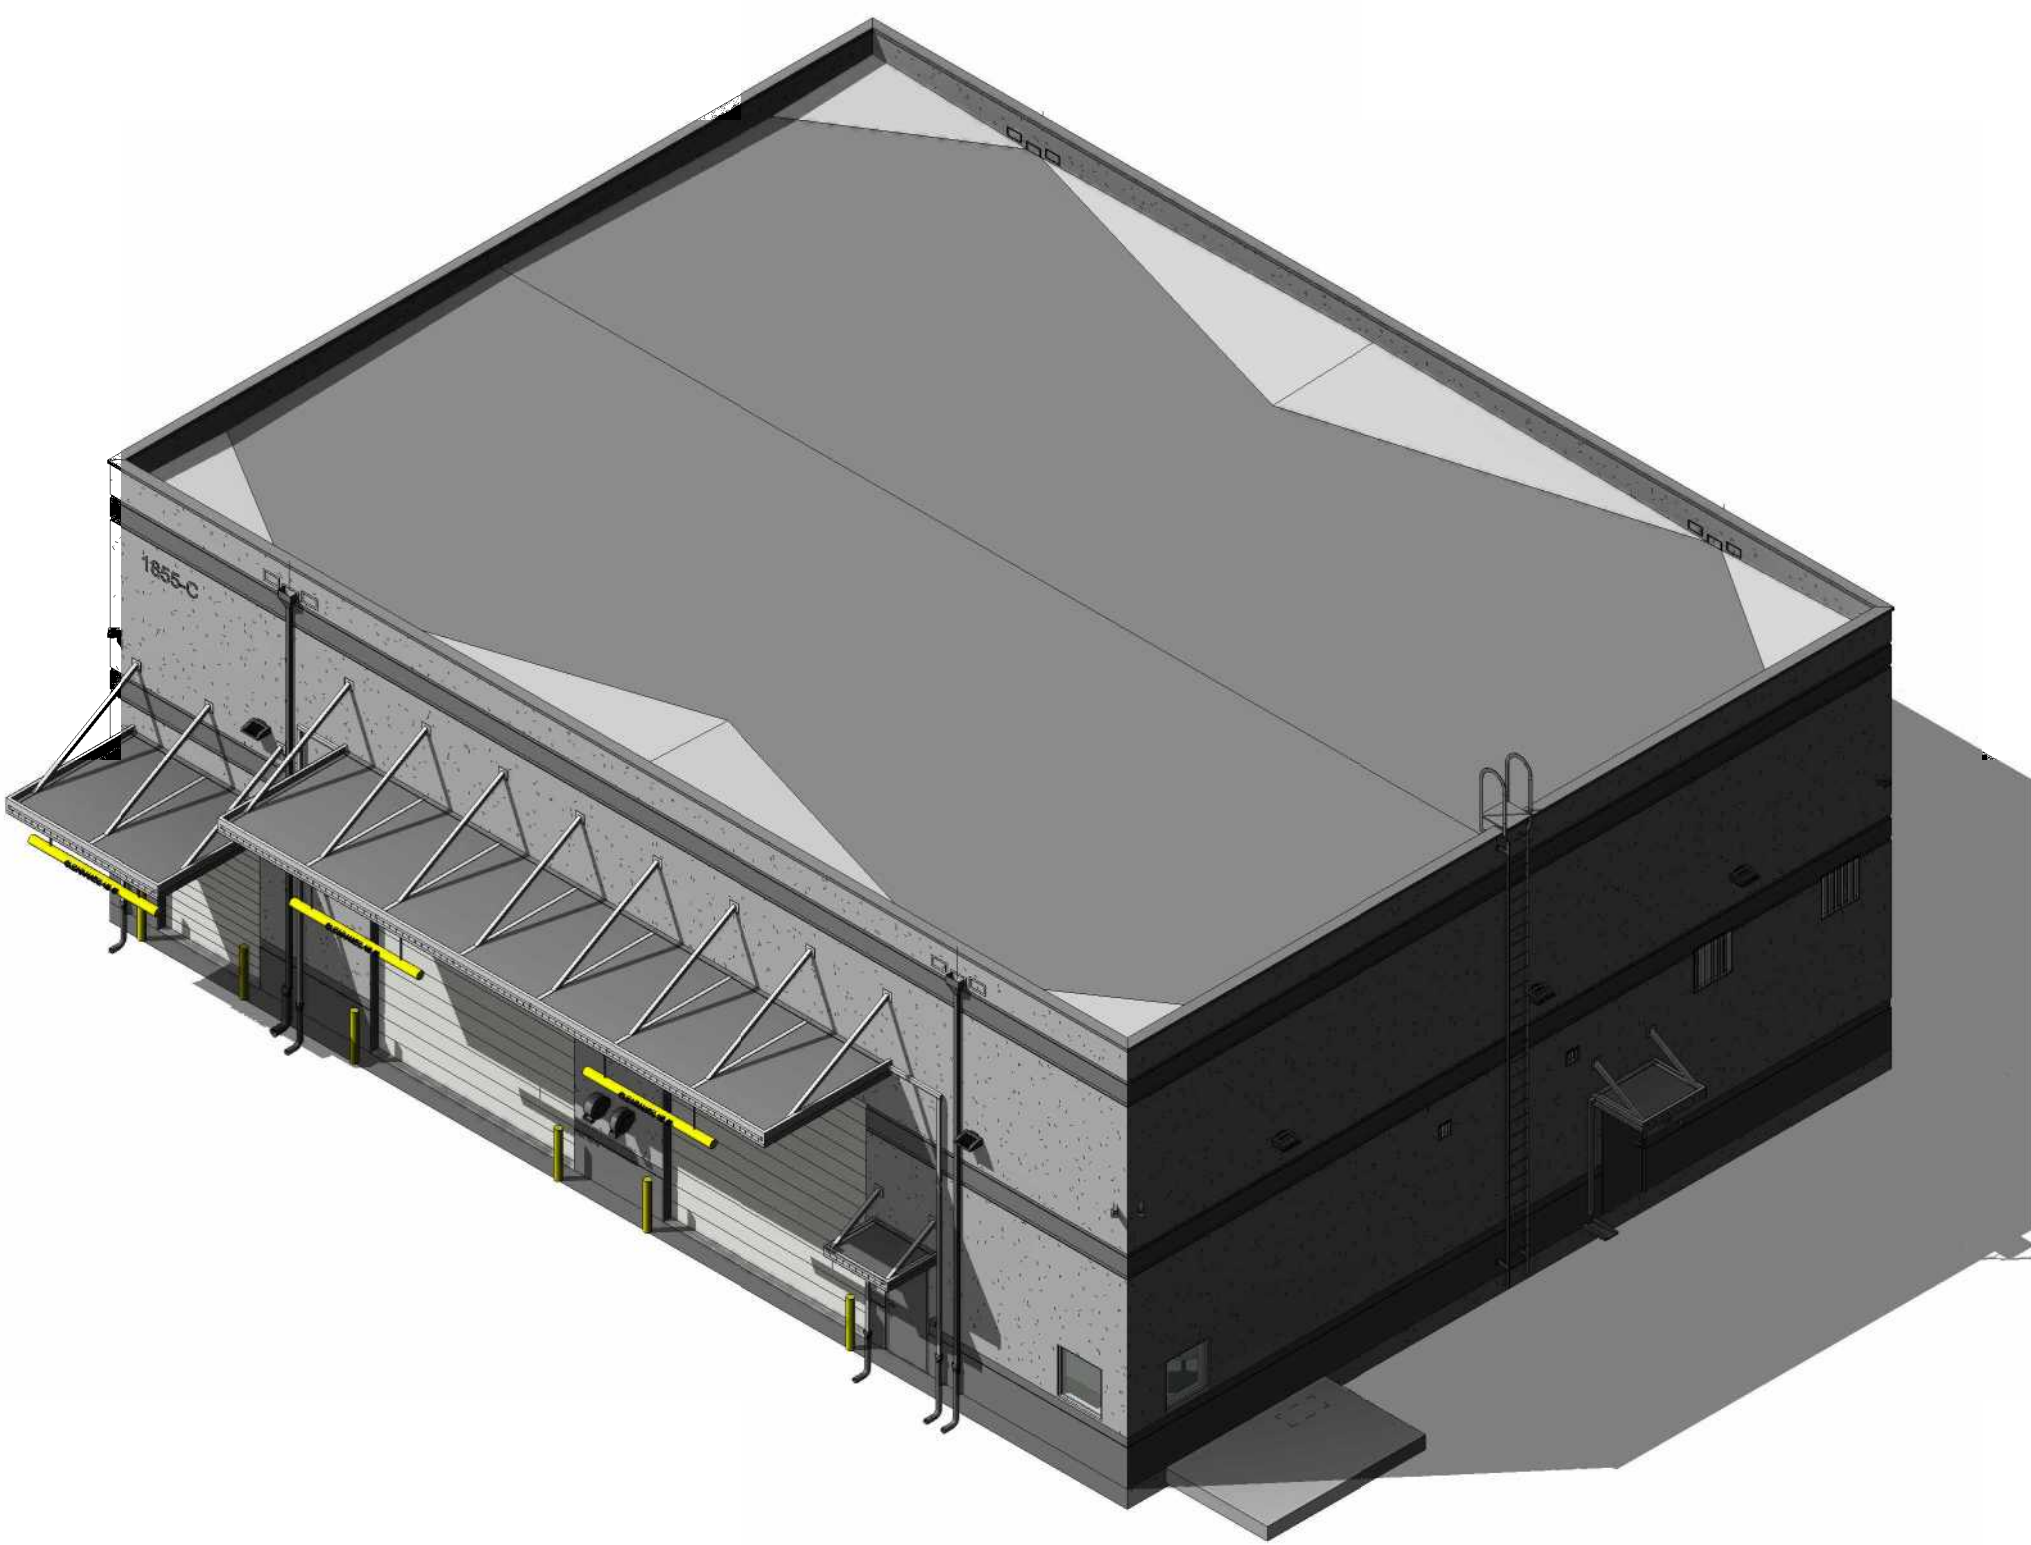

3D VIEW - BUILDING C

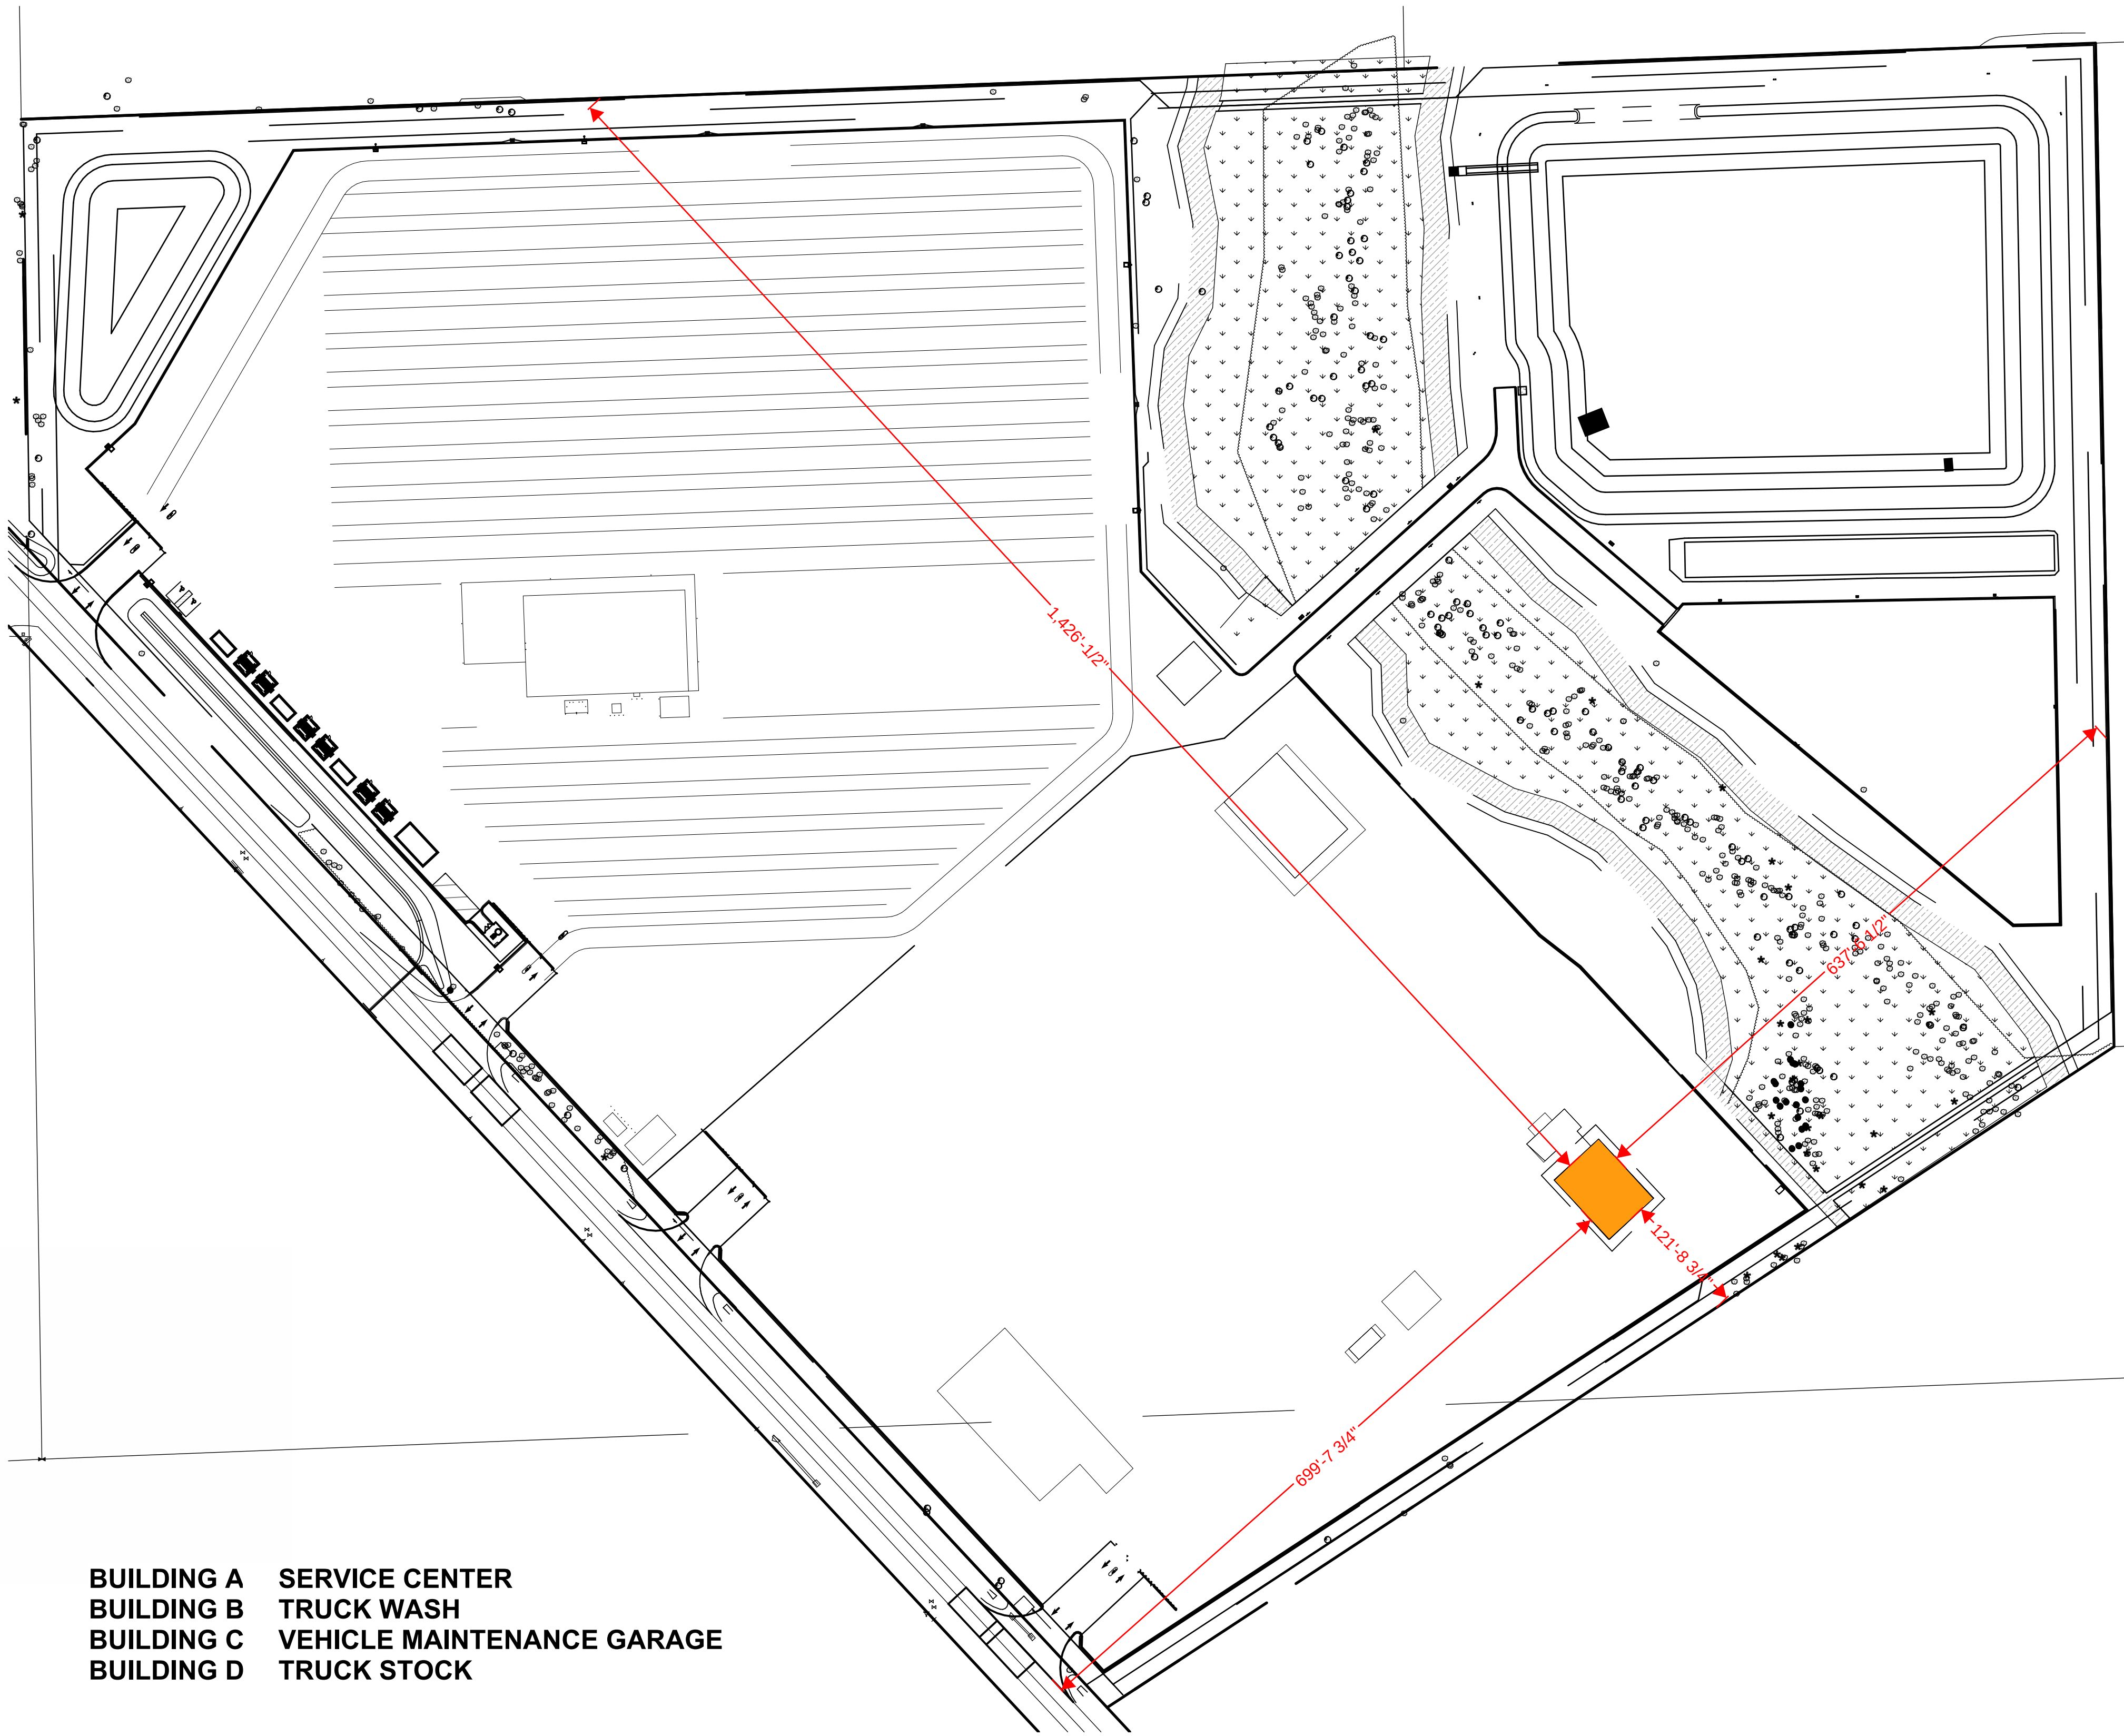

COVER SHEET PLAN
1" = 100'-0"

NOTE: REFER TO CIVIL DRAWINGS FOR SITE PERMIT DOCUMENTS.

BUILDING A SERVICE CENTER
BUILDING B TRUCK WASH
BUILDING C VEHICLE MAINTENANCE GARAGE
BUILDING D TRUCK STOCK

OWNER

FLORIDA POWER & LIGHT COMPANY

1655 S. FERDON BLVD.
CRESTVIEW, FL 32536
(561) 339-5349

JOEL JONES

ARCHITECTURE

LITTLE

201 S. ORANGE AVE, SUITE 800
ORLANDO, FL 32801
(407) 218-8286

SEAN TRACY

CIVIL/LANDSCAPE

KIMLEY HORN

12470 GRAN BAY PARKWAY WEST SUITE 107
2350
JACKSONVILLE, FL 32258
(904) 828-3927

CHRIS REUTHER

STRUCTURAL

JEZERINAC GROUP

480 HIBISCUS ST. SUITE 106
WEST PALM BEACH, FL 33401
(561) 746-8585

RONALD JEZERINAC

PLUMBING/MECHANICAL

CARDINAL ENGINEERING ASSOCIATES, INC.

575 NW MERCANTILE PL. SUITE 106
PORT ST. LUCIE, FL 34986
(561) 746-6343

SCOTT RAYNOR

ELECTRICAL

CARDINAL ENGINEERING ASSOCIATES, INC.

575 NW MERCANTILE PL. SUITE 106
PORT ST. LUCIE, FL 34986
(561) 746-6343

DAVID LITHGOW