

LEGEND

- EXIT LIGHT - ARROW REPRESENTS DIRECTION OF EXIT
- WALL MOUNT "ABC" FIRE EXTINGUISHER
- DOOR / CLOSER FOR EXITING OR RATING REASONS
- PRIMARY EGRESS w/ EXIT CAPACITY
- SECONDARY EGRESS
- EMERGENCY LIGHT w/ BATTERY BACKUP

NOTE: EMERGENCY LIGHTING AND EXIT SIGNS, SHALL BE PROVIDED AS DIRECTED BY THE FIRE MARSHAL AND SHALL BE WIRED PER NEC 700-21

NOTE: SMOKE DETECTORS SHALL BE MOUNTED NOT LESS THAN 5'0" ABOVE FINISHED FLOOR AND SHALL BE THE LONGSTAY TYPE, INTERLOCKED TOGETHER, POWERED FROM EACH STORE PANEL w/ BATTERY BACKUP

EXIT ACCESS TRAVEL DISTANCE PER FBC 109, TABLE 109.1
OCCUPANCY - BUSINESS
90 FT. (WITHOUT SPRINKLER SYSTEM)
250 FT. (WITH SPRINKLER SYSTEM)



LIFE SAFETY FLOOR PLAN
SCALE: 1/4" = 1'-0"

NOTE: TRAVEL DISTANCES SHOWN ARE MAXIMUM FOR EMERGENCY EGRESS. SECONDARY EGRESS AND NON-EMERGENCY EGRESS - ALL OTHER TRAVEL DISTANCES ARE LESS THAN THAT SHOWN



8" 60. MALTESE CROSS w/ "F" IDENTIFIER
SIGNAGE MOUNTED 4'-0" ABOVE GALLERY
LOCATE AS DIRECTED BY THE FIRE MARSHAL

2017 FBC-BUILDING, TABLE 1004.1.2
MAXIMUM FLOOR AREA ALLOWABLE PER OCCUPANT

OCCUPANCY CLASSIFICATION	FLOOR AREA	OCCUPANCY BASIS	NUMBER OF OCCUPANTS
STORAGE	3,342	• 1/300 SF	11
OFFICE	998	• 1/100 SF	9
SHOWROOM	415	• 1/60 SF	7
BATHROOM	145	• 1/PER BATH	2
BUILDING TOTALS	4,500		26



APPROVED (Subject to Revisions)
City Safety Services
City of Jacksonville Fire Marshal
Florida State Fire Marshal's Office
By: [Signature] Date: 07-11-2018

SCANNED

MIKE HALL
LAKE CITY, FLORIDA
GAMBLE CONSTRUCTION
8558 US-90, Lake Oak, FL 32060

JOINT VENTURED WITH
N3
NICHOLAS PAUL
GEISLER
ARCHITECT
1784 1st Street NE
Lake City, FL 32060
P: 407.344.0000

SHEET NUMBER
A.1
OF 4 SHEETS




COUNTY / CITY APPROVAL

639876




LEFT ELEVATION
SCALE: 1/8" = 1'-0"

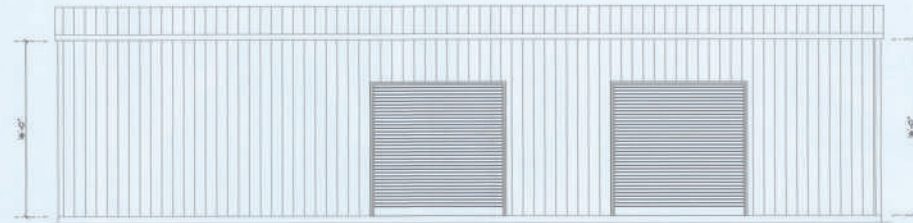

RIGHT ELEVATION
SCALE: 1/8" = 1'-0"



REAR ELEVATION
SCALE: 1/8" = 1'-0"

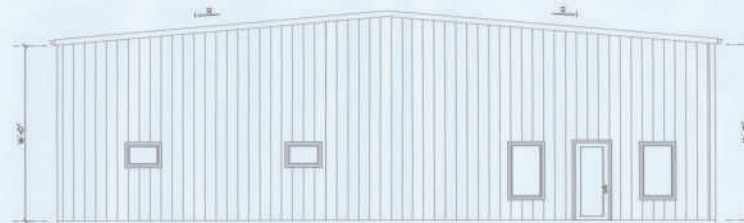

FRONT ELEVATION
SCALE: 1/8" = 1'-0"

MIKE HALL
LAKE CITY, FLORIDA
GAMBLE CONSTRUCTION
888 US-90, Lake Oak, FL 32060


N3
NICHOLAS
GERSLER
ARCHITECT
1000 Hill Street, Suite 200
Lake City, FL 32099
781.441.3444
www.n3architect.com

RIDGEPOINT DESIGN
ARCHITECTS
1000 Hill Street, Suite 200
Lake City, FL 32099
781.441.3444
www.ridgepointdesign.com

JOINT VENTURED WITH

SHEET NUMBER
A.2
OF 4 SHEETS

ARCHITECT
A.2
10/10/2019

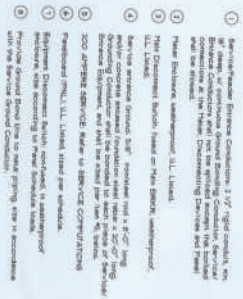

NOTE:
THE MINIMUM AIC RATING FOR PANEL BOARDS, BREAKERS
AND DISCONNECT SWITCHES SHALL BE 7500 AIC.

SERVICE SIZE W/ PARALLEL CONDUCTORS:
120/208V 3- ϕ - 500 - 200 AMPERS SERVICE
5 5/8" THRU CU - 1 9/16" THRU NEUT CU, 1 1/4" CU GND - 2 1/2" C.

Electrical Riser
DIAGRAM: 200A

SCALE: NONE

ELECTRICAL LEGEND					
ELECTRICAL	COUNT	SYMBOL	ELECTRICAL	COUNT	SYMBOL
LED CEILING MOUNT	6		INLET 220V	2	
WATERPROOF LED	6		OUTLET 20A	2	
EXTERIOR WALL SCIENCE	3		OUTLET 40A	4	
ELECTRIC PANEL	1		STANDARD LIGHT	8	
CABLE TV OUTLET	3		SWITCH	2	
EXHAUST FAN	3		SWITCH 3 WAY	3	
LAWN COMBINATION	3		WATER TIGHT LIGHT - SMALL	2	
OUTLET	38		LIGHTED EXIT SIGN - CEILING	4	

