

A CUSTOM HOME DESIGN FOR:

Scott Thomason

PROJECT ADDRESS:

911 SW ROBERTS AVE,
FT. WHITE, FLORIDA 32038
(COLUMBIA COUNTY)



SHEET INDEX

- A1 EXTERIOR ELEVATIONS
- A2 DIMENSIONED FLOOR PLAN
- A3 ELECTRICAL PLAN
- S1 FOUNDATION PLAN & DETAILS
- S2 ROOF PLAN, DETAILS & NOTES
- S3 WINDLOAD INFO, NOTES & DETAILS
- S4 FRAMING DETAILS & NOTES

AREA SUMMARY

LIVING AREA	2,304	S.F.
ENTRY PORCH AREA	96	S.F.
TOTAL AREA	2,400	S.F.

NOTE: ALL DRAWINGS NOT TO BE SCALED, WRITTEN DIMENSIONS TAKE PRECEDENCE OVER SCALED DIMENSIONS

REVISIONS

June 16, 2026

SOFTPLAN

ARCHITECTURAL DESIGN SOFTWARE

COVER PAGE

A CUSTOM HOME DESIGN FOR:

Scott Thomason

PROJECT ADDRESS: 911 SW ROBERTS AVE, FT. WHITE, FLORIDA 32038 (COLUMBIA COUNTY)

© WM DESIGN & ASSOCIATES, INC.

426 SW COMMERCE DR. STE 130

LAKE CITY, FL 32025

(386) 758-8406

wm@willmyers.net


JOB NUMBER
20260505

SHEET NUMBER
COVER


Will Myers



LEFT ELEVATION
SCALE: 1/4" = 1'-0"

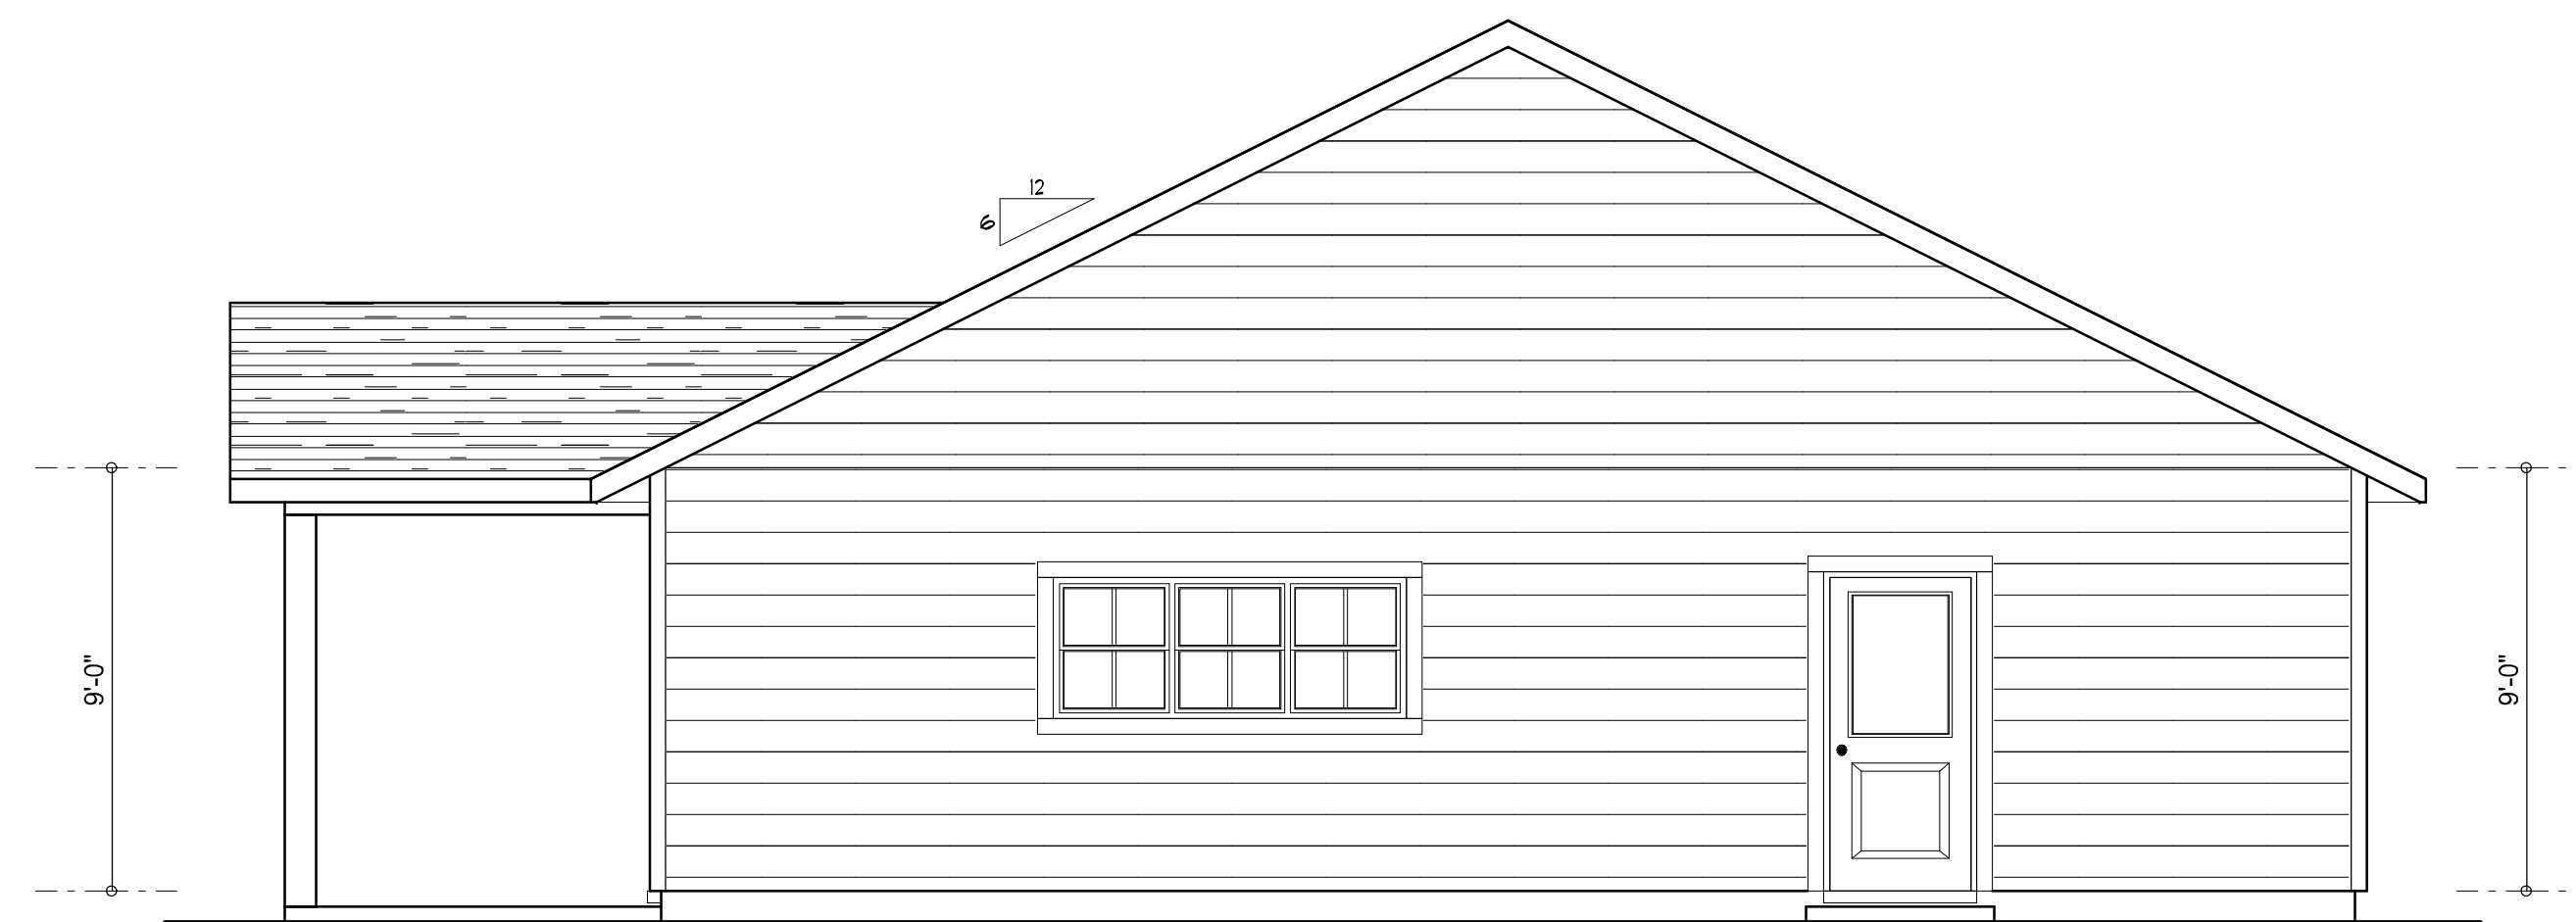

RIGHT ELEVATION
SCALE: 1/4" = 1'-0"

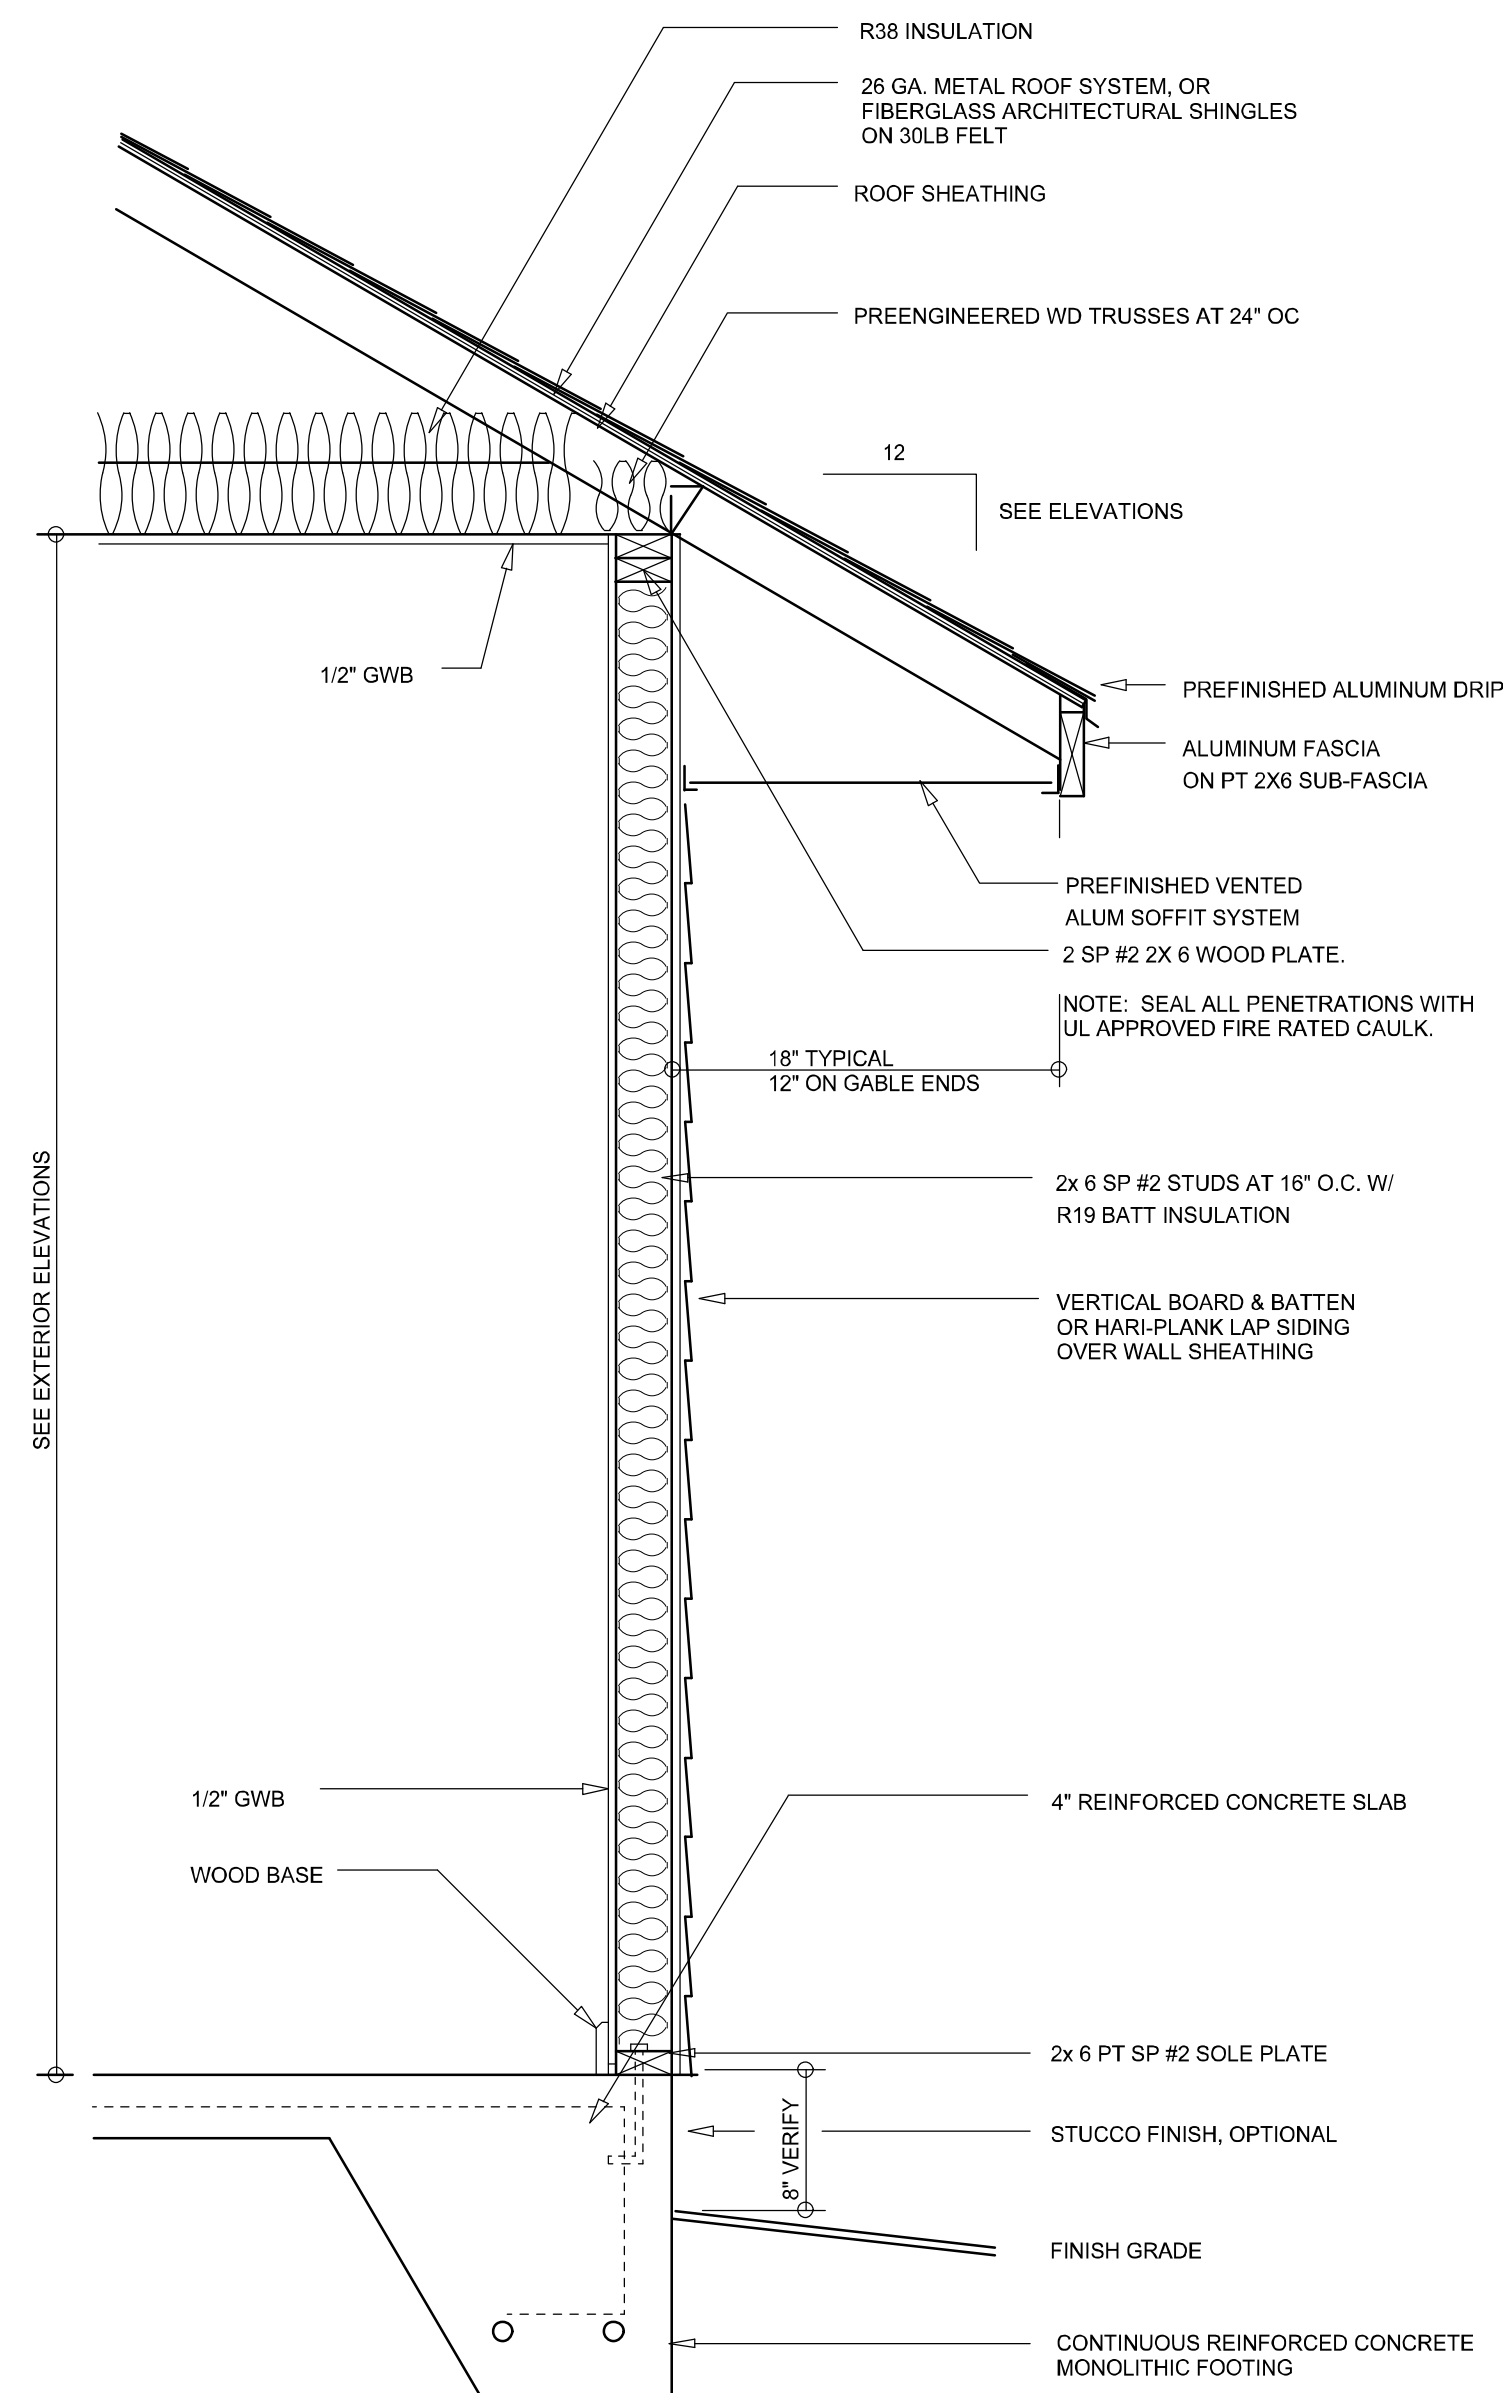

TYPICAL WALL SECTION
SCALE: 1" = 1'-0"



REAR ELEVATION
SCALE: 1/4" = 1'-0"



FRONT ELEVATION
SCALE: 1/4" = 1'-0"

NOTE: ALL DRAWINGS NOT TO BE SCALED, WRITTEN DIMENSIONS TAKE PRECEDENCE OVER SCALED DIMENSIONS

REVISIONS
June 16, 2026

SOFTPLAN
ARCHITECTURAL DESIGN SOFTWARE

EXTERIOR ELEVATIONS
SCALE: 1/4" = 1'-0"

TYPICAL WALL SECTION
SCALE: 1" = 1'-0"

A CUSTOM HOME DESIGN FOR:
Scott Thomason
PROJECT ADDRESS: 911 SW ROBERTS AVE. FT. WHITE, FLORIDA 32038 (COLUMBIA COUNTY)

© WM DESIGN & ASSOCIATES, INC.
426 SW COMMERCE DR. STE. 130
LAKE CITY, FL 32025
(386) 758-8406
wm@wmymyers.net




JOB NUMBER
20260505

SHEET NUMBER

A.1

Will C. Myers

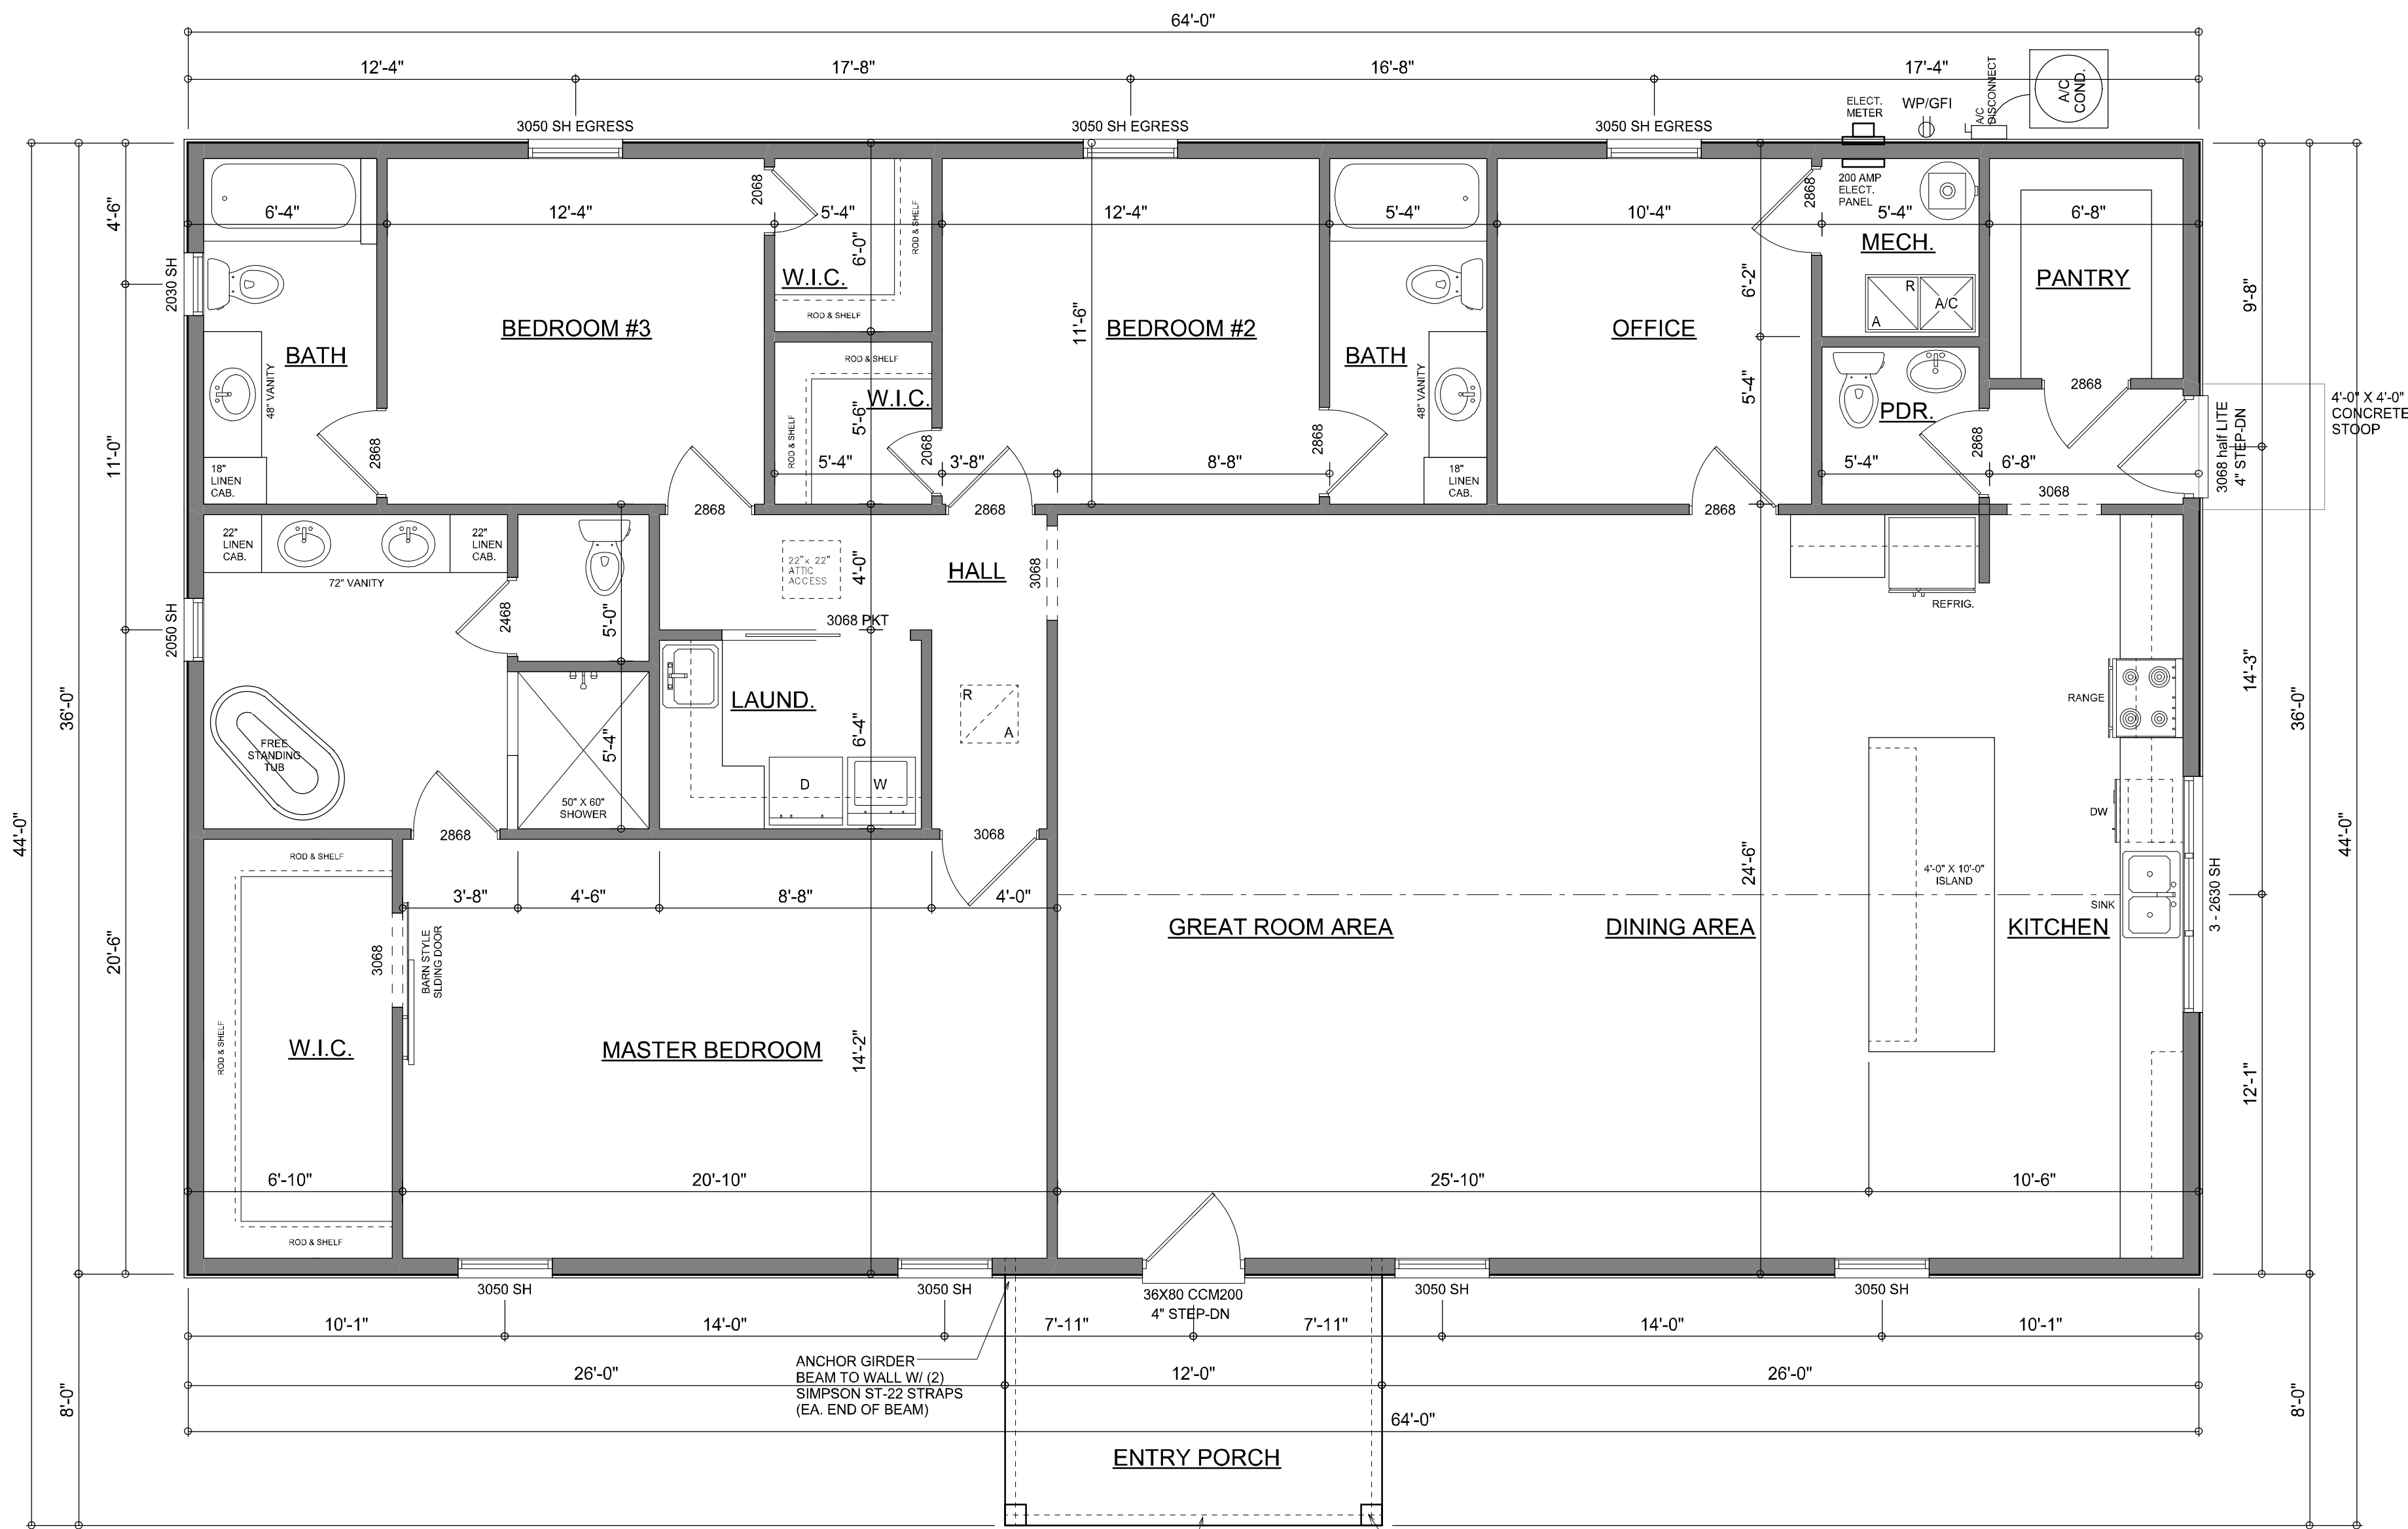

DIMENSIONED FLOOR PLAN
SCALE: 1/4" = 1'-0"
NOTE: ALL WALLS SHALL BE 9'-0" UNLESS OTHERWISE NOTED.

2 - 1 3/4" X 9 1/4" 2.0E MICRO-LAM L.V.L.
BEAM, EXTEND TOP PLY OF WALL PLATE
FULL LENGTH, LAP MIN. 32" TO ADJOINING
WALL, ASSEMBLE W/ 16d NAILS @ 12" O.C.,
STAGGERED TOP & BOTTOM OF BEAM,
EACH SIDE.
OPTIONAL:
DBL 2x 10 SP #2 WD GIRDER

4x 4 PT SP #2
WD POST, WRAPPED
TO 8" SQUARE, ANCHORED
W/ "SIMPSON" ABU44
POST BASE, 2 LOC.

AREA SUMMARY		
LIVING AREA	2,304	S.F.
ENTRY PORCH AREA	96	S.F.
TOTAL AREA	2,400	S.F.

Will C. Myers

REVISIONS
June 16, 2026

SOTPLAN
ARCHITECTURAL DESIGN SOFTWARE


 
DIMENSIONED FLOOR PLAN
SCALE: 1/4" = 1'-0"

A CUSTOM HOME DESIGN FOR:
Scott Thomason
PROJECT ADDRESS: 911 SW ROBERTS AVE, FT. WHITE, FLORIDA 32038 (COLUMBIA COUNTY)

© WM DESIGN & ASSOCIATES, INC.
426 SW COMMERCE DR. STE 130
LAKE CITY, FL 32025
(386) 758-8406
will@willmyers.net

JOB NUMBER
20260505

SHEET NUMBER
A.2

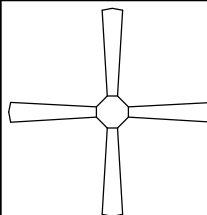ELECTRICAL LEGEND	
	CEILING FAN (PRE-WIRE FOR LIGHT KIT)
	DOUBLE SECURITY LIGHT
	RECESSED CAN LIGHT
	BATH EXHAUST FAN
	LIGHT FIXTURE
	DUPLEX OUTLET (AFCI & TAMPER RESISTANT)
	220v OUTLET
	GFI DUPLEX OUTLET (PER NEC 406.8)
	TELEVISION JACK
	ETHERNET JACK
	CIRCUIT FOR MINI-SPLIT A/C UNIT
	SMOKE / CARBON MONOXIDE DETECTOR (see note below)
	WALL SWITCH
	3 WAY WALL SWITCH
	WATER PROOF GFI OUTLET
	2 OR 4 TUB FLUORESCENT FIXTURE


NOTE:
ALL INTERIOR RECEPTACLES SHALL BE AFCI
(ARC FAULT CIRCUIT INTERRUPT) PER NEC 210.12 & TAMPER RESISTANT PER
NEC 406.11

ALL INTERIOR & EXTERIOR LIGHTING SHALL MEET OR EXCEED THE MIN. 75% HIGH-EFFICIENCY
LIGHTING PER FBC-ENERGY CONSERVATION R404.

ALL SMOKE DETECTORS BE A COMBO SMOKE & CARBON MONOXIDE DETECTOR
AND SHALL HAVE BATTERY BACKUP POWER
AND ALL WIRED TOGETHER SO IF ANY ONE UNIT IS ACTUATED THEY
ALL ACTIVATE.


THE ELECTRICAL SERVICE OVERCURRENT PROTECTION DEVICE SHALL BE
INSTALLED ON THE EXTERIOR OF STRUCTURES TO SERVE AS A DISCONNECT MEANS.
CONDUCTORS USED FROM THE EXTERIOR DISCONNECTING MEANS TO A PANEL OR SUB
PANEL SHALL HAVE FOUR-WIRE CONDUCTORS, OF WHICH ONE CONDUCTOR
SHALL BE USED AS AN EQUIPMENT GROUND.

IT IS THE LICENSED ELECTRICAL CONTRACTORS RESPONSIBILITY TO INSURE THAT ALL
WORK PERFORMED AND EQUIPMENT INSTALLED MEETS OR EXCEEDS THE 2020 (NFPA-70) NATIONAL
ELECTRIC CODE AND ALL OTHER LOCAL CODES AND ORDINANCES.

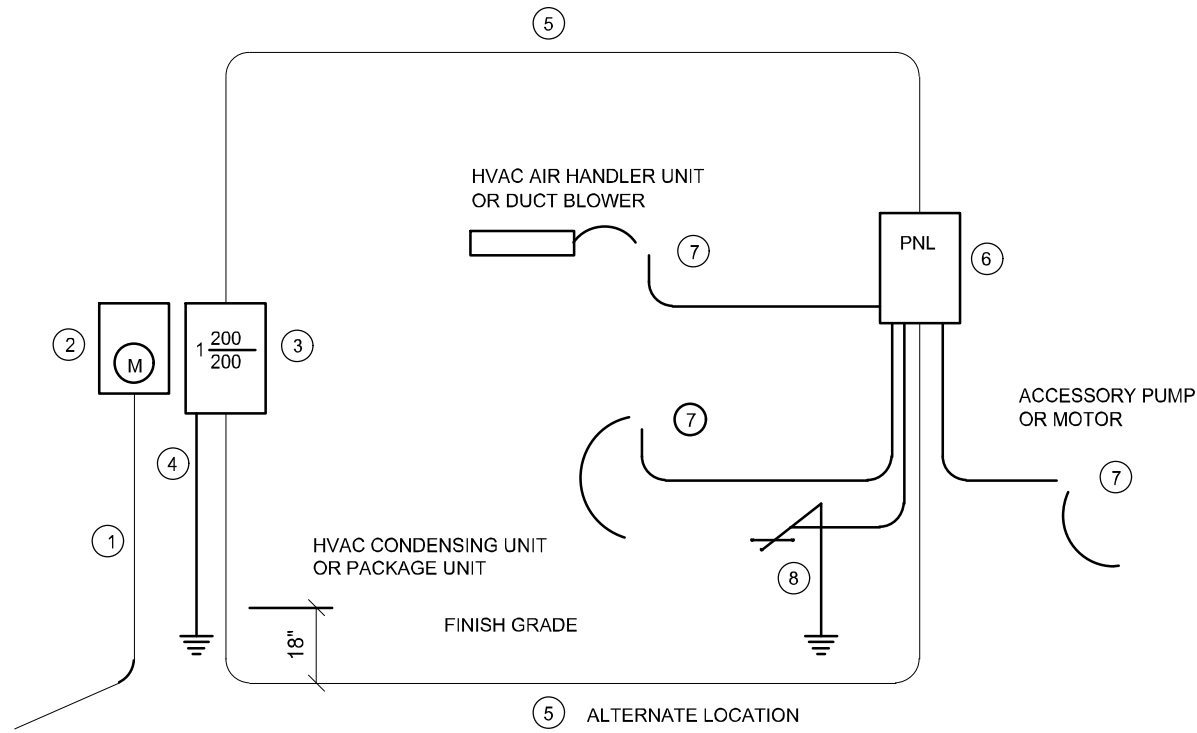

- Service/Feeder Entrance Conductors: 2\"/>
- Meter Enclosure, weatherproof, U.L. Listed.
- Main Disconnect Switch: fused or Main BRKR, weatherproof, U.L. Listed.
- Service entrance Ground: 1\"/>
- 200 AMPERE SERVICE: 3-#2/0-USE-Cu, 1-#4-Cu-GND, 2\"/>
- House Panel (PNL), U.L. Listed, sized per schedule.
- Equipment Disconnect Switch: non-fused, in weatherproof enclosure, size according to Panel Schedule loads.
- Provide Ground Bond Wire to metal piping, size in accordance with the Service Ground Conductor.

NOTE:
THE MINIMUM AIC RATING FOR PANEL BOARDS, BRKRS
AND DISCONNECT SWITCHES SHALL BE 22,000 AIC.

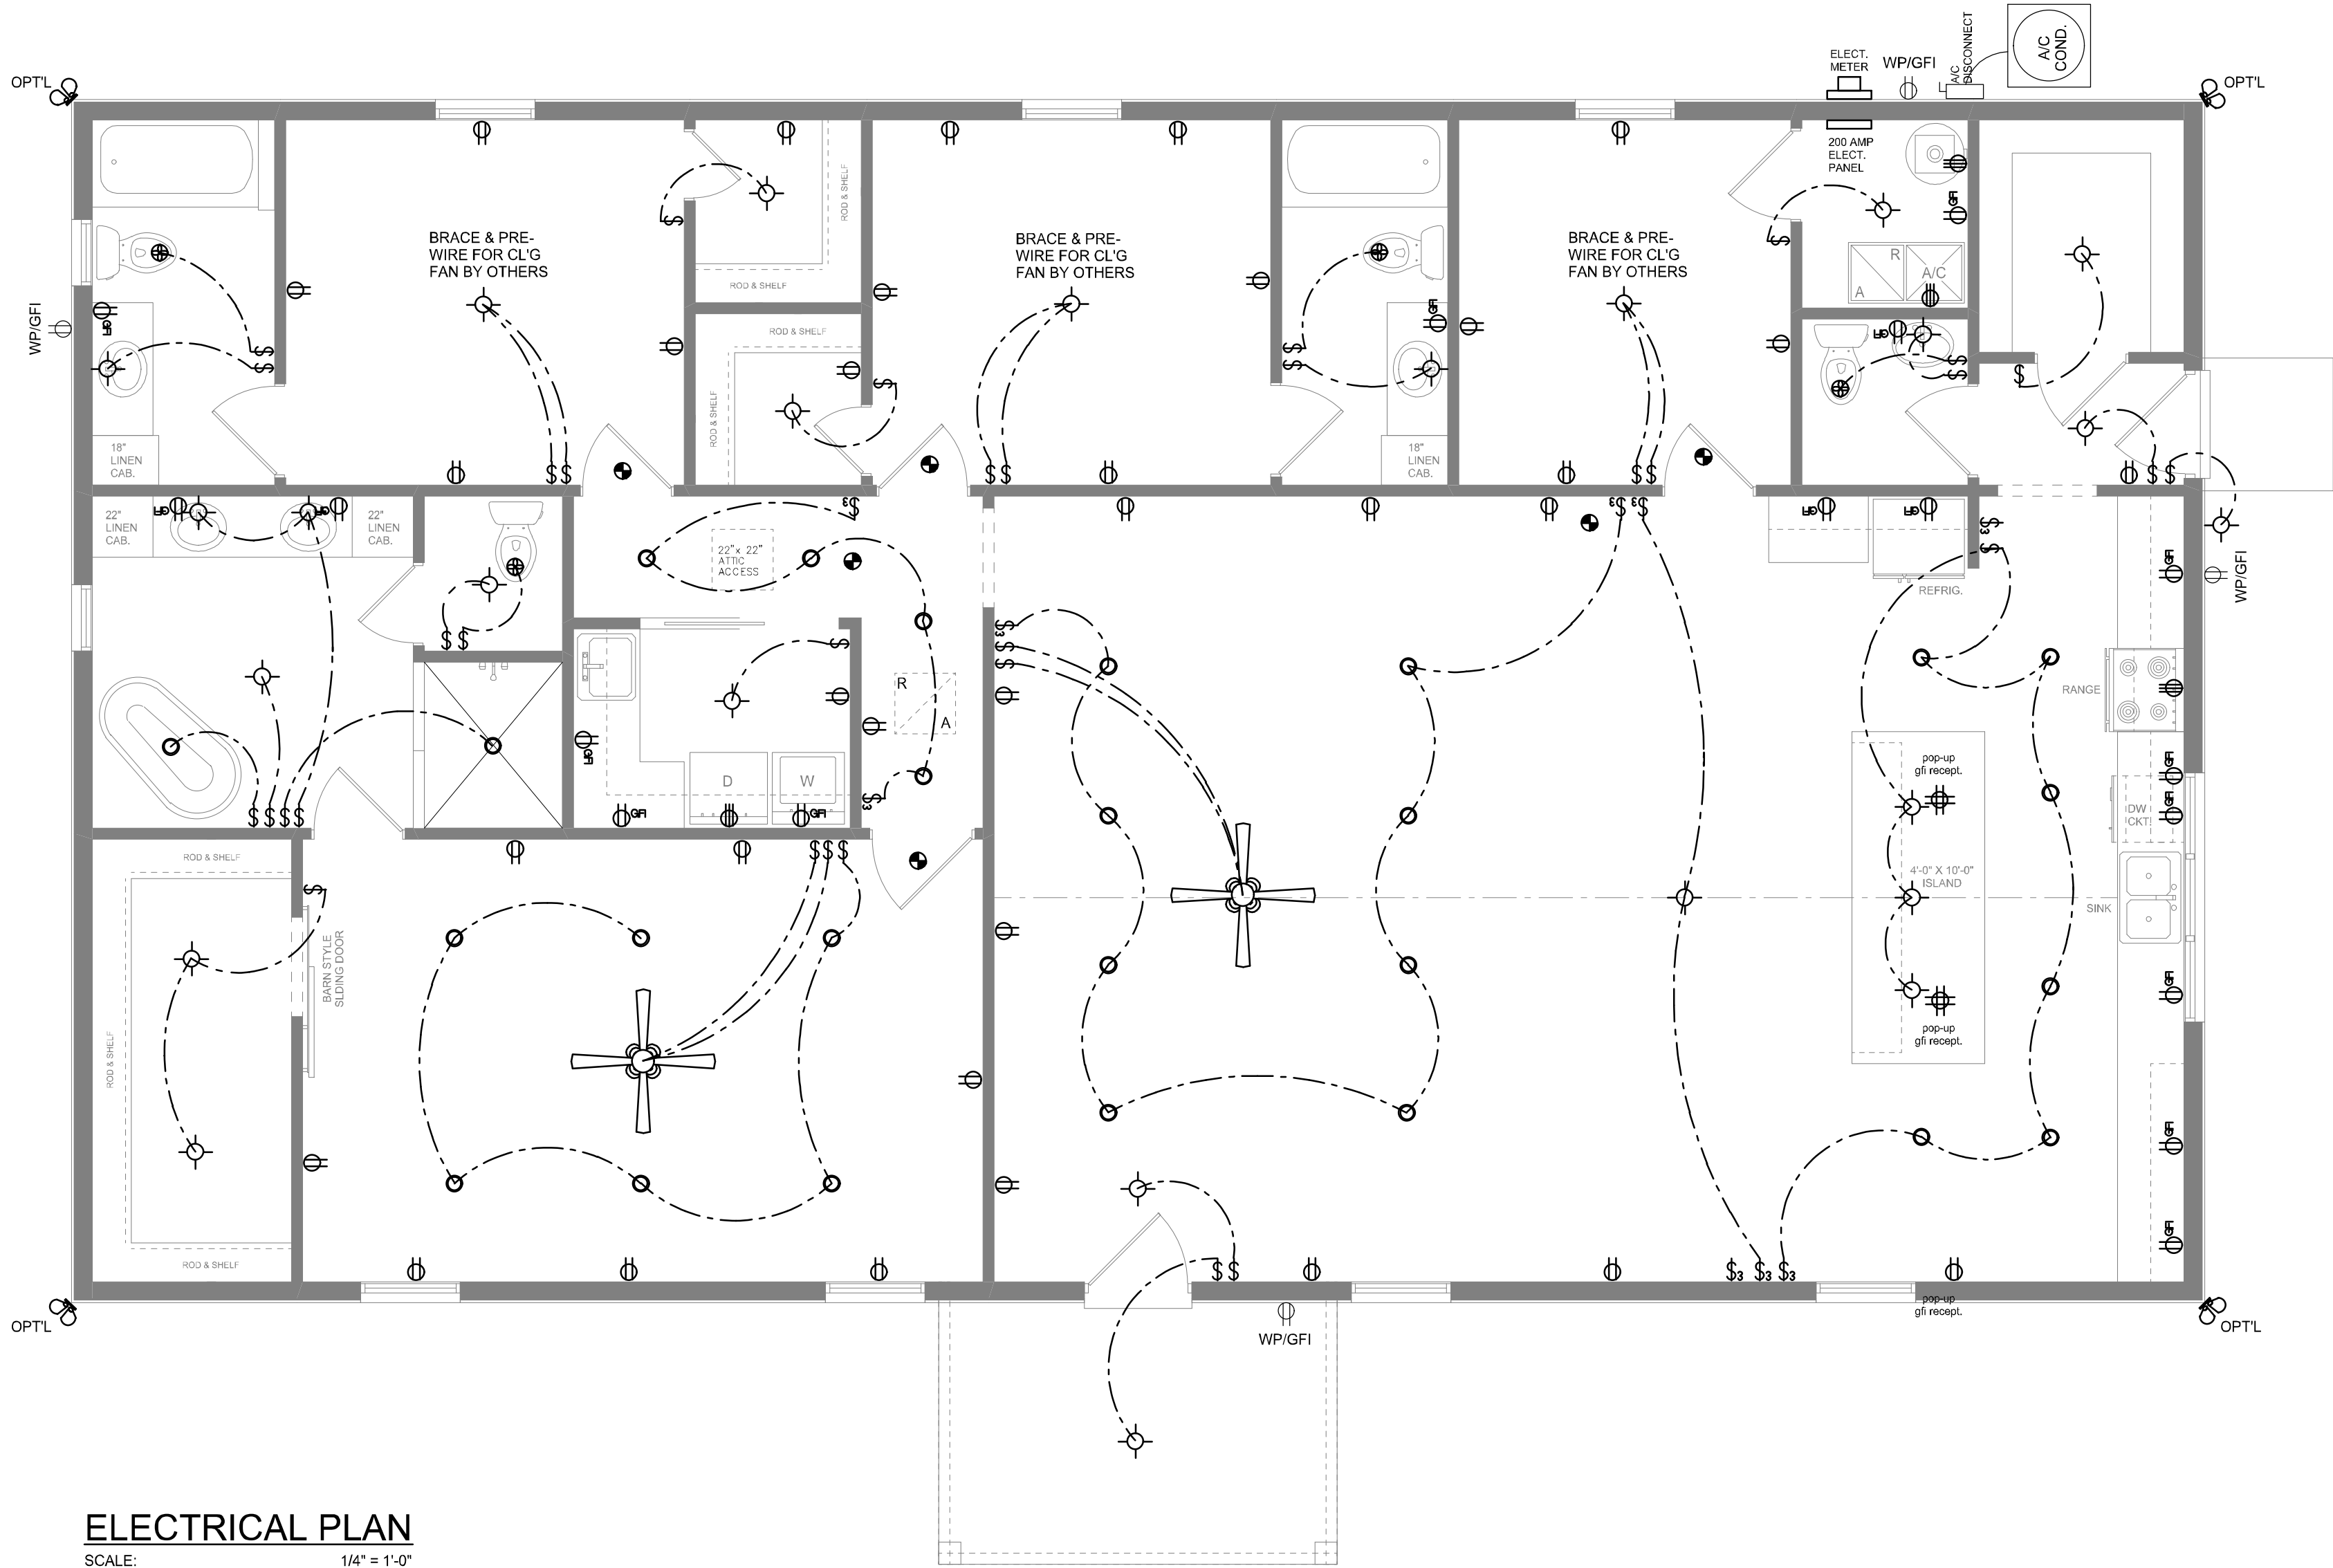

ELECTRICAL PLAN
SCALE: 1/4" = 1'-0"

NOTE: ALL DRAWINGS NOT TO BE SCALED, WRITTEN DIMENSIONS TAKE PRECEDENCE OVER SCALED DIMENSIONS

REVISIONS

June 16, 2026

SOFTPLAN

ARCHITECTURAL DESIGN SOFTWARE

ELECTRICAL PLAN

SCALE: 1/4" = 1'-0"

A CUSTOM HOME DESIGN FOR:

Scott Thomason

PROJECT ADDRESS: 911 SW ROBERTS AVE, FT. WHITE, FLORIDA 32038 (COLUMBIA COUNTY)

© WM DESIGN & ASSOCIATES, INC.

426 SW COMMERCE DR. STE 130

LAKE CITY, FL 32025

(386) 758-8406

wm@willmyers.net

W

M

JOB NUMBER

20260505

SHEET NUMBER

A.3

Wm C. Myers