

ALL REPAIR, SPECIFICATIONS, COMPUTER FILES, FIELD DATA AND OTHER DOCUMENTATION PREPARED BY KASPER ARCHITECTURE & DEVELOPMENT, INC. (KAD) IS INSTRUMENTS OF SERVICE SHALL REMAIN THE PROPERTY OF KAD. KAD SHALL RETAIN ALL COMMON LAW, STATUTORY AND OTHER RESERVED RIGHTS, INCLUDING THE COPYRIGHT THEREIN. THIS DRAWING SHALL NEVER BE REPRODUCED IN WHOLE OR IN PART WITHOUT THE EXPRESS WRITTEN PERMISSION OF KAD.

PLUMBING FIXTURE SCHEDULE							
DESIGNATION	MANUFACTURER	MODEL #	FIXTURE DESCRIPTION	CONNECTION SCHEDULE			
				WASTE	VENT	CW	HW
WC	KOHLER	K-84325 HIGHLINE	1.6/1.1 FLUSH VALVE TYPE WALL MOUNTED WATER CLOSET WITH SLOAN ECOS 111 HARDWIRED - 1.6/1.1 - HW SENSOR FLUSHOMETER. PROVIDE EL-451 TRANSFORMER SERVING (3) 18 GAUGE WIRE FROM TRANSFOER TO FLUSHOMETER MAINLINE ML 1055SSC000 WHITE ENLOGATED PLASTIC OPEN FRONT TOILET SEAT WITH SELF SUSTAINING CHECK HINGE. PROVIDE BARIATRIC WALL HANGER.	3"	2"	1"	--
UR	KOHLER	BARDON K-4904-ET	TOP SPUD URINAL WITH SLOAN ECOS 186 HARDWIRED - 1.0-OR-HW 1.0 GPF FLUSHOMETER. PROVIDE EL-452 TRANSFORMER SERVING (4) URINALS, AND PROVIDE (4) 18 GAUGE WIRE FROM TRANSFORMER TO FLUSHOMETER. PROVIDE WALL HANGER.	2"	2"	1"	--
L-1	DECOLAV	1300	WITH KOHLER K-13462 AC POWERED SENSOR FAUCET, UNDERMOUNT LAVATORY. DECOLAV 9295 GRID DRAIN, 301PC P-TRAP, PROVIDE ASSE 1070 THERMOSTATIC MIXING VALVE, SET OUTLET TEMPERATURE TO 100 F.	2"	1 1/2"	1/2"	1/2"
L-2	KOHLER	SOHO K-2054-0	WITH KOHLER K-13462 AC POWERED SENSOR FAUCET, KEENEY 5700PC DRAIN, 301PC P-TRAP, TRUEBRO LAV GUARD E-2 SERIES WHITE. PROVIDE ASSE 1070 THERMOSTATIC MIXING VALVE, SET OUTLET TEMPERATURE TO 100 F.	2"	1 1/2"	1/2"	1/2"
HB	WOODFORD	B65	ANTI-SIPHON FREEZELESS WALL HYDRANT.	--	--	3/4"	--
HS-1	ADVANCE TABCO	7-PS-18	PEDESTAL MOUNTED BAS TYPE 304 STAINLESS STEEL 16"x14"x6" DEEP BOWL, SPLASH MOUNTED GOOSENECK FAUCET, BASKET DRAIN, PEDAL VALVES	1 1/2"	1 1/2"	1/2"	1/2"
HS-2	EAGLE GROUP	SR19-16-13.5-1	PEDESTAL MOUNTED BAS TYPE 304 STAINLESS STEEL, WITH DECK MOUNTED FAUCET, SWING NOZZEL, BASKET DRAIN, PROVIDE THERMOSTATIC MIXING VALVE, SET OUTLET TEMPERATURE TO 105 F.	1 1/2"	1 1/2"	1/2"	1/2"
KS-1	ADVANCE TABCO	9-3-54-18L	16"x20"x14" 3 COMPARTMENT SINK WITH 18" LEF SIDE DRAIN BOARD, 8" BACKLASH, STAINLESS STEEL CONSTRUCTION.	3"	1 1/2"	1/2"	1/2"
KS-2	ADVANCE TABCO	9-3-54-18L	16"x20"x14" 3 COMPARTMENT SINK WITH DRAIN BOARD ON BOTH SIDES, 8" BACKLASH, STAINLESS STEEL CONSTRUCTION.	3"	1 1/2"	1/2"	1/2"
MS-1	ADVANCE TABCO	9-OP-28	FLOOR-MOUNTED MOP SINK WITH BOWL 20"x28"x8" BOWL SIZE, TILE EDGE FURNISHED ON THE REAR. FAUCET-FIAT 830-AA FURNISH WALL-MOUNTED MOP HANGER	3"	1 1/2"	3/4"	3/4"
MS-2	ADVANCE TABCO	9-OP-28	FLOOR-MOUNTED MOP SINK WITH BOWL 20"x28"x8" BOWL SIZE, TILE EDGE FURNISHED ON THE REAR. FAUCET-FIAT 830-AA FURNISH WALL-MOUNTED MOP HANGER	3"	1 1/2"	3/4"	3/4"
FS-1	JOSAM	FS-143	12"x12"x8" PORCELAIN COATED CAST IRON FLOOR SINK, NO-HUB BOTTOM OUTLET, ALUMINUM DOME STRAINER, AND 3" WASTE CONNECTION.	3"	1 1/2"	--	--
EW-C-1	ELKAY	EZH20	ELECTRIC WATER COOLER w/BARRIER FREE ACCESS, ADA COMPLIANT, B-LEVEL WITH BOTTLE FILLER	2"	1 /12"	1/2"	--
FD	ZURN	Z-415 W/ TYPE "B" STRAINER	FLOOR DRAIN W/ 5" NICKALOY STRAINER TOP PROVIDE AUXILIARY INLET FITTING FOR TRAP PRIMER CONNECTION	3"	--	--	--
SH-1	SEE ARCHITECTURAL PLANS	SEE ARCHITECTURAL PLANS	SHOWER VALVE: SYMONS MODEL 4700S-PS-X-1.5 SHOWER VALVE WITH LEVER HANDLE, PRESSURE BALANCING MIXING VALVE ADJUSTABLE STOP SCORE, INTERGRAL SERVICES STOP, 1.5 GPM FLOW RATE, POLISHED CHROM FINISH, OUTLET DIVERTER DRAIN: ZURN MODEL F22259	2"	1 1/2"	1/2"	1/2"
SH-2	SEE ARCHITECTURAL PLANS	SEE ARCHITECTURAL PLANS	SHOWER VALVE: SYMONS MODEL 4700S-PS-X-1.5 SHOWER VALVE WITH LEVER HANDLE, PRESSURE BALANCING MIXING VALVE ADJUSTABLE STOP SCORE, INTERGRAL SERVICES STOP, 1.5 GPM FLOW RATE, POLISHED CHROM FINISH, OUTLET DIVERTER DRAIN: ZURN MODEL F22259	2"	1 1/2"	1/2"	1/2"
TP-1	ZURN	Z-1022	AUTOMATIC TRAP PRIMER WITH INTEGRAL VACUUM BREAKER AND GASKETED COVER. PROVIDE CHROME PLATED FINISH FOR EXPOSED INSTALLATIONS AND ACCESS DOOR FOR CONCEALED INSTALLATIONS. PROVIDE DU-MULTIPLE OUTLET CONNECTION FOR TRAP PRIMERS SERVING MORE THAN ONE DRAIN.	--	--	1/2"	--
FCO	ZURN	Z-1400	FLOOR CLEANOUT - PROVIDE SCREW COVER MATCH SIZE OF PIPE.	--	--	--	--
WCO	ZURN	Z-1446	WALL CLEANOUT - PROVIDE SCREW COVER MATCH SIZE OF PIPE.	--	--	--	--
WF	EVERPURE	EV9437-10	HIGH FLOW CBR QUSO-MC2 SYSTEM WITH MAXIMUM FLOW RATE OF 6.7 GPM.	--	--	3/4"	3/4"
AAV	STUDOR	MAXI OR MINI VENT	AIR ADMITTANCE VALVE	--	"SEE PLANS"	--	--
GWH-1	A.O. SMITH	BTH-150	100-GALLON COMMERCIAL GAS WATER HEATER, 150 MBH, 120-1-60, 178 GPH @ 100 F RISE SET WATER TEMP. CONTROL TO 120 F.	--	--	1-1/4"	1-1/4"
GWH-2	A.O. SMITH	BTX-80	55-GALLON GAS WATER HEATER, 60 MBH, 120-1-60, 86GPH @ 100 F RISE SET WATER TEMP. CONTROL TO 110° F	--	--	3/4"	3/4"
NFRH	MAPA	MPH-34D	NON-FREEZE ROOF HYDRANT	--	--	3/4"	--
AD-1	ZURN	Z181	6" DIAMETER CAST IRON BODY, 3" BOTTOM OUTLET, 4" BRONZE DOME WITH STAINLESS STEEL MESH SCREEN, BRONZE FLASHING CLAMP.	3"	--	--	--
HD-1	WATTS	FD-100-DD	FLOOR DRAIN - OPEN SITE HUB DRAIN, CAST IRON BODY, SEDIMENT BUCKET, 3" BOTTOM OUTLET. TRAP SEAL - 3", PLASTIC HOUSING WITH FLEXIBLE DIAPHRAGM, SEALING GASKETS, RECLOSES AND SEALS WHEN DISCHARGE IS COMPLETED, ASSE 1072.	3"	--	--	--
TD-1	JR SMITH	9870-451-SSPA	TRENCH DRAIN - MODULAR, PRE-SLOPED, HEAVY DUTY POLYPROPYLENE, 6" WIDE CHANNEL, 0.6% SLOPE, INTEGRAL CATCH BASINS WITH SEDIMENT BUCKETS, 4" OUTLETS, LENGTH AS SHOWN ON DRAWINGS. GRATE - STAINLESS STEEL, CLASS A, PERFORATED PATTERN. PRIOR TO ORDERING PRODUCT, MANUFACTURER TO PROVIDE SUBMITTAL LAYOUT DRAWINGS SHOWING INDIVIDUAL TRENCH SECTIONS, LENGTHS, OUTLET LOCATIONS, CATCH BASINS AND DIMENSIONS COORDINATED WITH PROJECT LAYOUT.	3"	--	--	--
RD-1	WATTS	RD-300	ROOF DRAIN - CAST IRON BODY, SECURED CAST IRON DOME, 15" ROUND, BOTTOM OUTLET, FLASHING CLAMP, GRAVEL STOP, UNDERDECK CLAMP, BEARING PAN, ADJUSTABLE EXTENSION TO MATCH INSULATION THICKNESS, OUTLET SIZE AS LISTED ON DRAWINGS.	3"	--	--	--
ORD-1	WATTS	RD-300	ROOF DRAIN - CAST IRON BODY, SECURED CAST IRON DOME, 15" ROUND, BOTTOM OUTLET, FLASHING CLAMP, GRAVEL STOP, UNDERDECK CLAMP, BEARING PAN, EXTENSION TO MATCH INSULATION THICKNESS, 4" TALL EXTERNAL WATER DAM, OUTLET SIZE AS LISTED ON DRAWINGS.	3"	--	--	--
RDO	ZURN	Z199	ROOF DRAIN OUTLET - LAMBS TONGUE DOWNSPOUT NOZZLE, BRONZE BODY, INTEGRAL ANCHORING FLANGE, SOLVENT CEMENT PVC OR SET SCREW CONNECTION TYPE, OUTLET SIZE AS LISTED ON DRAWINGS. ADDITIONAL REQUIREMENTS: REMOVABLE STAINLESS STEEL BIRD SCREEN	3"	--	--	--
WS	CULLIGAN	CTM-300PF	PRE-PIPED AND SKID MOUNTED, DUPLEX SOFTENER TANKS, AUTOMATIC REGENERATION TYPE BASED ON VOLUMETRIC TOTAL, POWER SUPPLY WITH CORD AND PLUG. CONTINUOUS FLOW RATE OF 140 GPM AT 15 PSI PRESSURE DROP MAXIMUM FLOW RATE OF 190 GPM AT 25 PSI PRESSURE DROP SALT DOSAGE OF 10 LBS PER CUBIC FOOT OF RESIN SOFTENER TANK SIZE: 24" DIAMETER BRINE TANK SIZE: 24" DIAMETER ELECTICAL REQUIREMENTS - PROVIDE ONE RECEPTACLE PER CONTROL VALVE.	--	--	3"	--
RCP	TACO	008	DOMESTIC HOT WATER RECIRCULATION PUMP 4 GPM AT 10 FT. HD. 1/25 HP, 115 VOLTS, .79 FULL LOAD AMPS	--	--	--	--

PLUMBING GENERAL NOTES

- IN THE PREPARATION OF THESE PLANS, THE ENGINEER HAS USED CERTAIN ABBREVIATIONS, CONVENTIONS, AND SYMBOLS, THE MEANING OF WHICH ARE ILLUSTRATED AND EXPLAINED WITHIN THE LEGEND.
- PLANS ARE DIAGRAMMATIC ONLY. THEY ARE INTENDED TO INDICATE CAPACITY, SIZE, LOCATION, DIRECTION AND GENERAL ARRANGEMENT, BUT NOT EXACT DETAILS OF CONSTRUCTION. THE FACT THAT ONLY CERTAIN FEATURES OF THE INSTALLATION ARE INDICATED MUST NOT BE TAKEN TO MEAN THAT OTHER FEATURES WILL NOT BE REQUIRED.
- COORDINATE WITH THE OTHER TRADES TO ENSURE THAT EACH TRADE SHALL HAVE SUFFICIENT SPACE TO INSTALL THEIR EQUIPMENT (DUCTWORK, PIPING, ELECTRICAL WORK, ETC.).
- ONCE THE PIPING HAS ENTERED EACH UNIT FROM BELOW THE FLOOR SLAB, PIPING SHALL BE RUN ABOVE THE CEILING IN EACH UNIT UNLESS NOTED OR INDICATED OTHERWISE.
- VERIFY ALL DIMENSIONS FROM ARCHITECTURAL PLANS AND FIELD DIMENSIONS.
- ALL RISES AND DROPS IN PIPING ARE NOT NECESSARILY SHOWN.
- PROVIDE STOP OR ANGLE VALVES ON EACH WATER CONNECTION TO EACH PLUMBING FIXTURE.
- PROVIDE ALL STRUCTURAL MEMBERS, SUPPORT BRACKETS, FLASHING, HARDWARE, ETC. REQUIRED TO INSTALL A COMPLETE SYSTEM.
- PROVIDE CHROME PLATED ESCUTCHEON PLATES AT ALL EXPOSED WALL PENETRATIONS AND CEILING PENETRATIONS.
- PROVIDE CLEANOUTS ON SANITARY LINES AND CONDENSATE DRAIN LINES AS REQUIRED BY CODE.
- PROVIDE ACCESS PANELS FOR ALL SHUT-OFF VALVES LOCATED ABOVE GYPSUM BOARD CEILINGS. COORDINATE WITH GENERAL CONTRACTOR.



ABBREVIATIONS

A/C	ABOVE CEILING
AFF	ABOVE FINISHED FLOOR
AFG	ABOVE FINISHED GRADE
BFF	BELOW FINISHED FLOOR
BFG	BELOW FINISHED GRADE
BTU	BRITISH THERMAL UNIT
CO	CLEANOUT
CONN	CONNECTION
CW	COLD WATER
DN	DOWN
DFU	DRAINAGE FIXTURE UNIT
ED	EQUIPMENT DRAIN
EX	EXISTING
FU	FIXTURE UNIT
FL	FLOOR
FCO	FLOOR CLEANOUT
GPM	GALLONS PER MINUTE
GC	GENERAL CONTRACTOR
GCO	GRADE CLEANOUT
GW	GREASE WASTE
HW	HOT WATER
HWR	HOT WATER RETURN
IE	INVERT ELEVATION
IN	INCHES
MIN	MINIMUM
OST	OVERFLOW STORM
PC	PLUMBING CONTRACTOR
SAN or S	SANITARY
ST	STORM
V	VENT
VTR	VENT TO ROOF
WCO	WALL CLEANOUT
W	WASTE
WTR	WATER
WSFU	WATER SUPPLY FIXTURE UNIT
w/	WITH
w/O	WITHOUT

GENERAL SYMBOLS

	PLAN OR DETAIL NO. SHEET NUMBER
	KEYED NOTE TO PLAN
	REVISION NUMBER
	NORTH ARROW

PLUMBING SYMBOL LEGEND

	COLD WATER PIPE
	HOT WATER PIPE
	HOT WATER RETURN PIPE
	EXISTING COLD WATER PIPE
	EXISTING HOT WATER PIPE
	EXISTING HOT WATER RETURN PIPE
	SOIL OR WASTE PIPE
	EXISTING SOIL OR WASTE PIPE
	VENT PIPE
	EXISTING VENT PIPE
	CHILLED WATER RETURN PIPE
	CHILLED WATER SUPPLY PIPE
	CONDENSER WATER PIPE
	COOLING WATER RETURN PIPE
	COOLING WATER SUPPLY PIPE
	STORM
	FIRE
	TURNUED UP
	TURNUED DOWN
	TEE, OUTLET DOWN
	TEE, OUTLET UP
	TEMPERATURE AND PRESSURE RELIEF DRAIN PIPING
	EMERGENCY DRAIN PAN PIPING
	GATE VALVE
	PRESSURE RELIEF VALVE
	BALL VALVE
	PLUMBING FIXTURE DESIGNATION (UNDER LINED)
	CONNECT TO EXISTING
	DISCONNECT FROM EXISTING
	MEDICAL GAS PIPE
	NATURAL GAS PIPE
	COMPRESSED AIR PIPE

PLUMBING FIXTURE DEMAND TABULATION

Project Name: Busy Bee Ellisville						BUILDING TYPE: NEW						
Project No.: 23000902						PREDOMINANTLY: FLUSH VALVE						
FIXTURE	DESCRIPTION	OCCUPANCY	QTY.	DRAINAGE FIXTURE UNITS	SUB- TOTAL	LOAD VALUES IN WATER (EACH) SUPPLY FIXTURE UNITS (WSFU)			LOAD VALUES IN WATER (TOTAL) SUPPLY FIXTURE UNITS (WSFU)			Remarks
						COLD	HOT	TOTAL	COLD	HOT	TOTAL	
WC-1	Water Closet, Flush Valve, 1.6 gpf	Public	51	4	204	10.0	-	10.0	510	0	510	
UR	Urinal, 3/4" Flush Valve	Public	14	4	56	5.0	-	5.0	70	0	70	
L-1	Lavatory ADA	Public	60	1	60	1.5	1.5	2.0	90	90	120	
L-2	Hand Wash Sink	Public	3	1	3	1.5	1.5	2.0	4.5	4.5	6	
SH-1	Shower	Public	8	2	16	2.3	2.3	3.0	18.4	18.4	24	
S-1	Kitchen Sink (2/3-Compartment)		2	2	4	2.3	2.3	3.0	4.6	4.6	6	
MS	Mop Sink		1	2	2	2.3	2.3	3.0	2.3	2.3	3	
IMB	Ice Maker Valve Box-(Refrigerator / Ice Maker)	Public	0	0	0.3	-	-	0.3	0	0	0	
FD1	Floor Drain - General / Restroom		19	2	38	0.0	0.0	0.0	0	0	0	
FS	Floor Sink		2	2	4	0.0	0.0	0.0	0	0	0	
HB	Hose Bibb	Public	0	0	0	2.0	-	2.0	0	0	0	
EWC	Electric Water Cooler (Drinking Fountain)	Offices, etc.	0	0.5	0	0.3	-	0.3	0	0	0	
TOTALS					387	DFU			699.8	119.8	739	WSFU
DFU = DRAINAGE FIXTURE UNITS					EIGHTH	INCH SLOPE PER FOOT			170.2	72.9	175.5	GPM
WSFU = WATER SUPPLY FIXTURE UNITS					5	DIAMETER OF PIPE (INCHES)			3	2	3	INCHES REQ'D.



10175 Fortune Parkway, Suite 701
Jacksonville, FL 32256
p 904.683.9201 f 904.683.9702

www.kasperarch.com
FL License No.: AA2600802



www.IMEGCorp.com
9133 E.G. Shuman Parkway
Jacksonville, Florida 32256
Ph: (904) 481-5200 Fax: (904) 481-6700
email: msh@McVighMangum.com
CA 6330
Eng. of Record: David D. Dowell
License No.: 78366

BUSY BEE ELLISVILLE

136 SW WEBBS GLN
LAKE CITY, FL 32024

PROJECT NO.: 22024

DATE: 04/10/2025

PRIOR ISSUES:

NOTES, LEGENDS, & SYMBOLS

P0.1


DRAWN BY: DD

CHECKED BY: TF

DESIGN DEVELOPMENT

NOT FOR CONSTRUCTION

ALL RETAIL, SPECIFICATIONS, COMPUTER FILES, FIELD DATA AND OTHER DOCUMENTATION PREPARED BY KASPER ARCHITECTURE & DEVELOPMENT, INC. (KAD) IS INHERENTLY OF SERVICE SHALL REMAIN THE PROPERTY OF KAD. KAD SHALL RETAIN ALL COMMON LAW, STATUTORY AND OTHER RESERVED RIGHTS, INCLUDING THE COPYRIGHT THEREIN. THIS DRAWING SHALL NOT BE REPRODUCED IN WHOLE OR IN PART WITHOUT THE EXPRESS WRITTEN PERMISSION OF KAD.

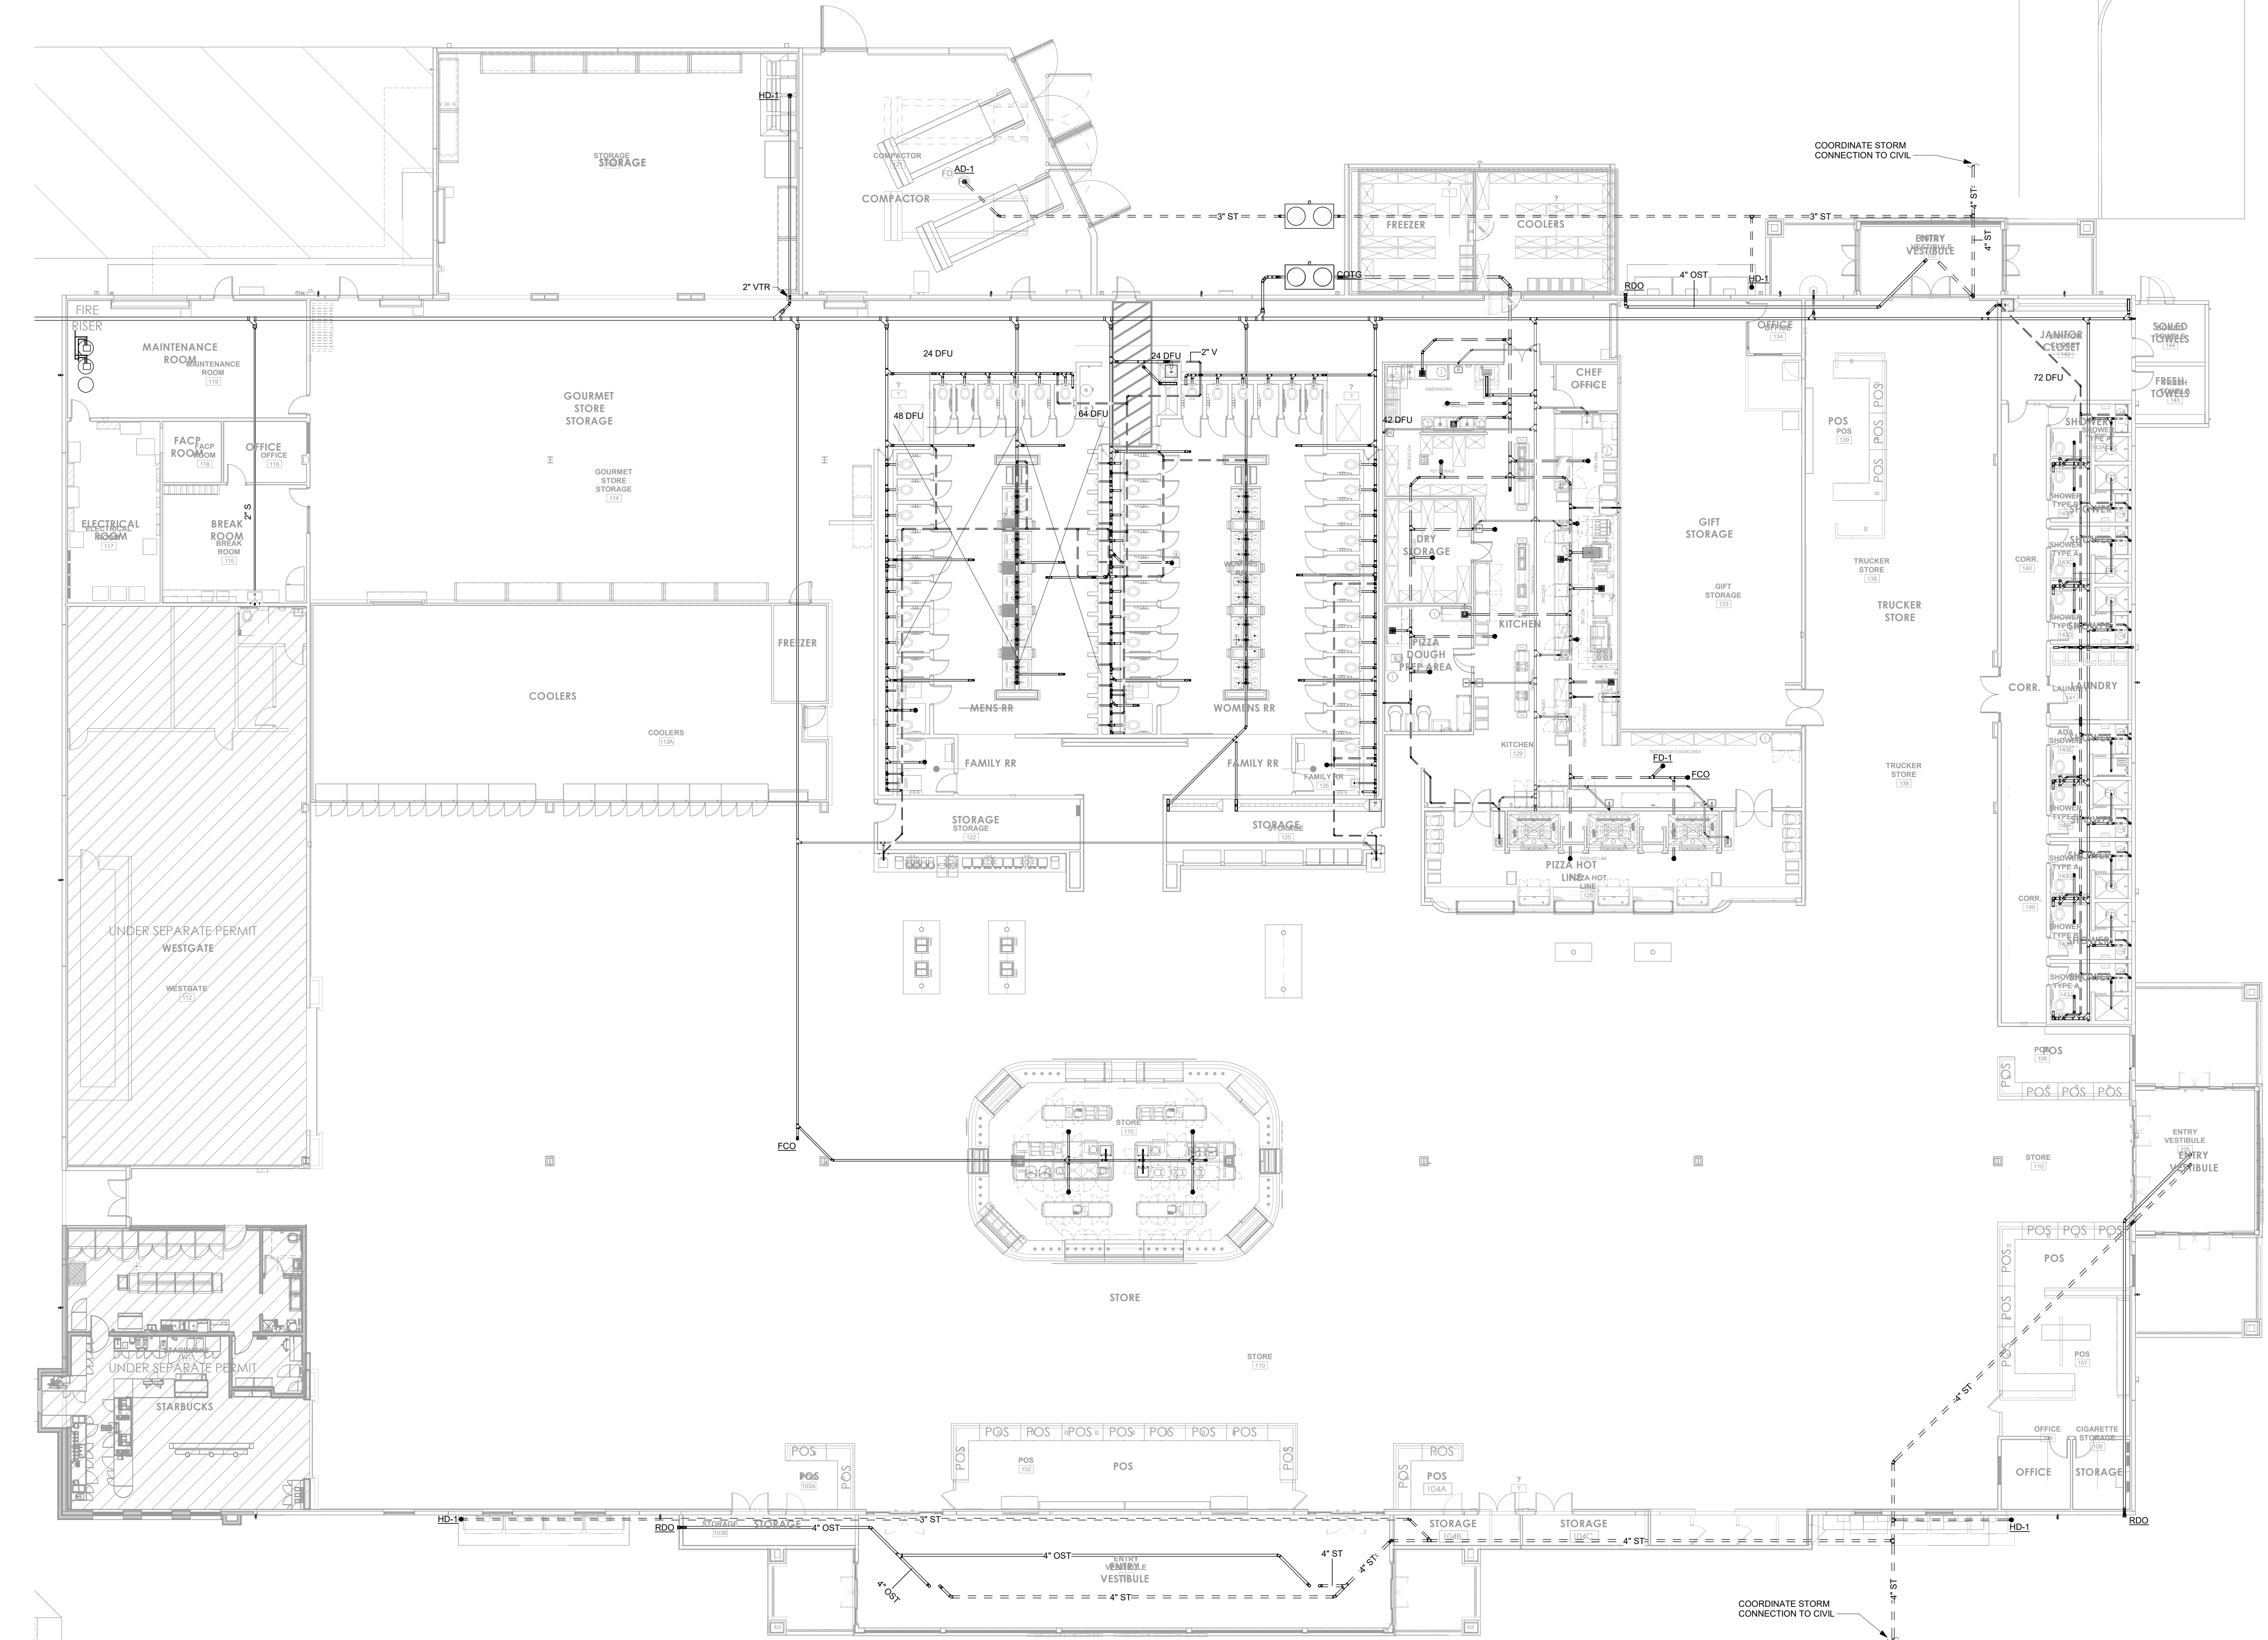

1 RETAIL STORE OVERALL DWV FLOOR PLAN
P1.1
SCALE: 3/32" = 1'-0"


NOT FOR CONSTRUCTION



10175 Fortune Parkway, Suite 701
Jacksonville, FL 32256
p 904.683.9201 f 904.683.9702
www.kasperarch.com
FL License No.: AA2600802



www.IMEGcorp.com
9133 E.G. Sasser Parkway
Jacksonville, Florida 32256
Ph: (904) 483-5700 Fax: (904) 436-6700
email: multi@McVeighMangum.com
CA 6330
Eng. of Record: David D. Dowell
License No.: 78366

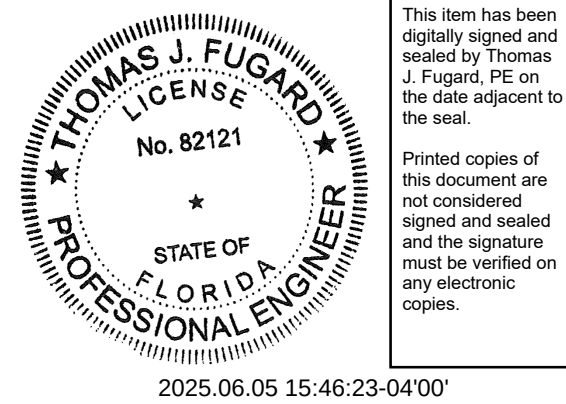

BUSY BEE ELLISVILLE

136 SW WEBBS GLN
LAKE CITY, FL 32024

PROJECT NO.: 22024

DATE: 04/10/2025

PRIOR ISSUES:

RETAIL STORE OVERALL DWV FLOOR PLAN

P1.1


DRAWN BY: DD

CHECKED BY: TF

DESIGN DEVELOPMENT

ALL RETAIL SPECIFICATIONS, COMPUTER FILES, FIELD DATA AND OTHER DOCUMENTATION PREPARED BY KASPER ARCHITECTURE & DEVELOPMENT, INC. (KAD) IS INSTRUMENTS OF SERVICE SHALL REMAIN THE PROPERTY OF KAD. KAD SHALL RETAIN ALL COMMON LAW, STATUTORY AND OTHER RESERVED RIGHTS, INCLUDING THE COPYRIGHT THEREIN. THIS DRAWING SHALL NEVER BE REPRODUCED IN WHOLE OR IN PART WITHOUT THE EXPRESS WRITTEN PERMISSION OF KAD.

1
P1.2
RETAIL STORE OVERALL DW FLOOR PLAN
SCALE: 3/32" = 1'-0"

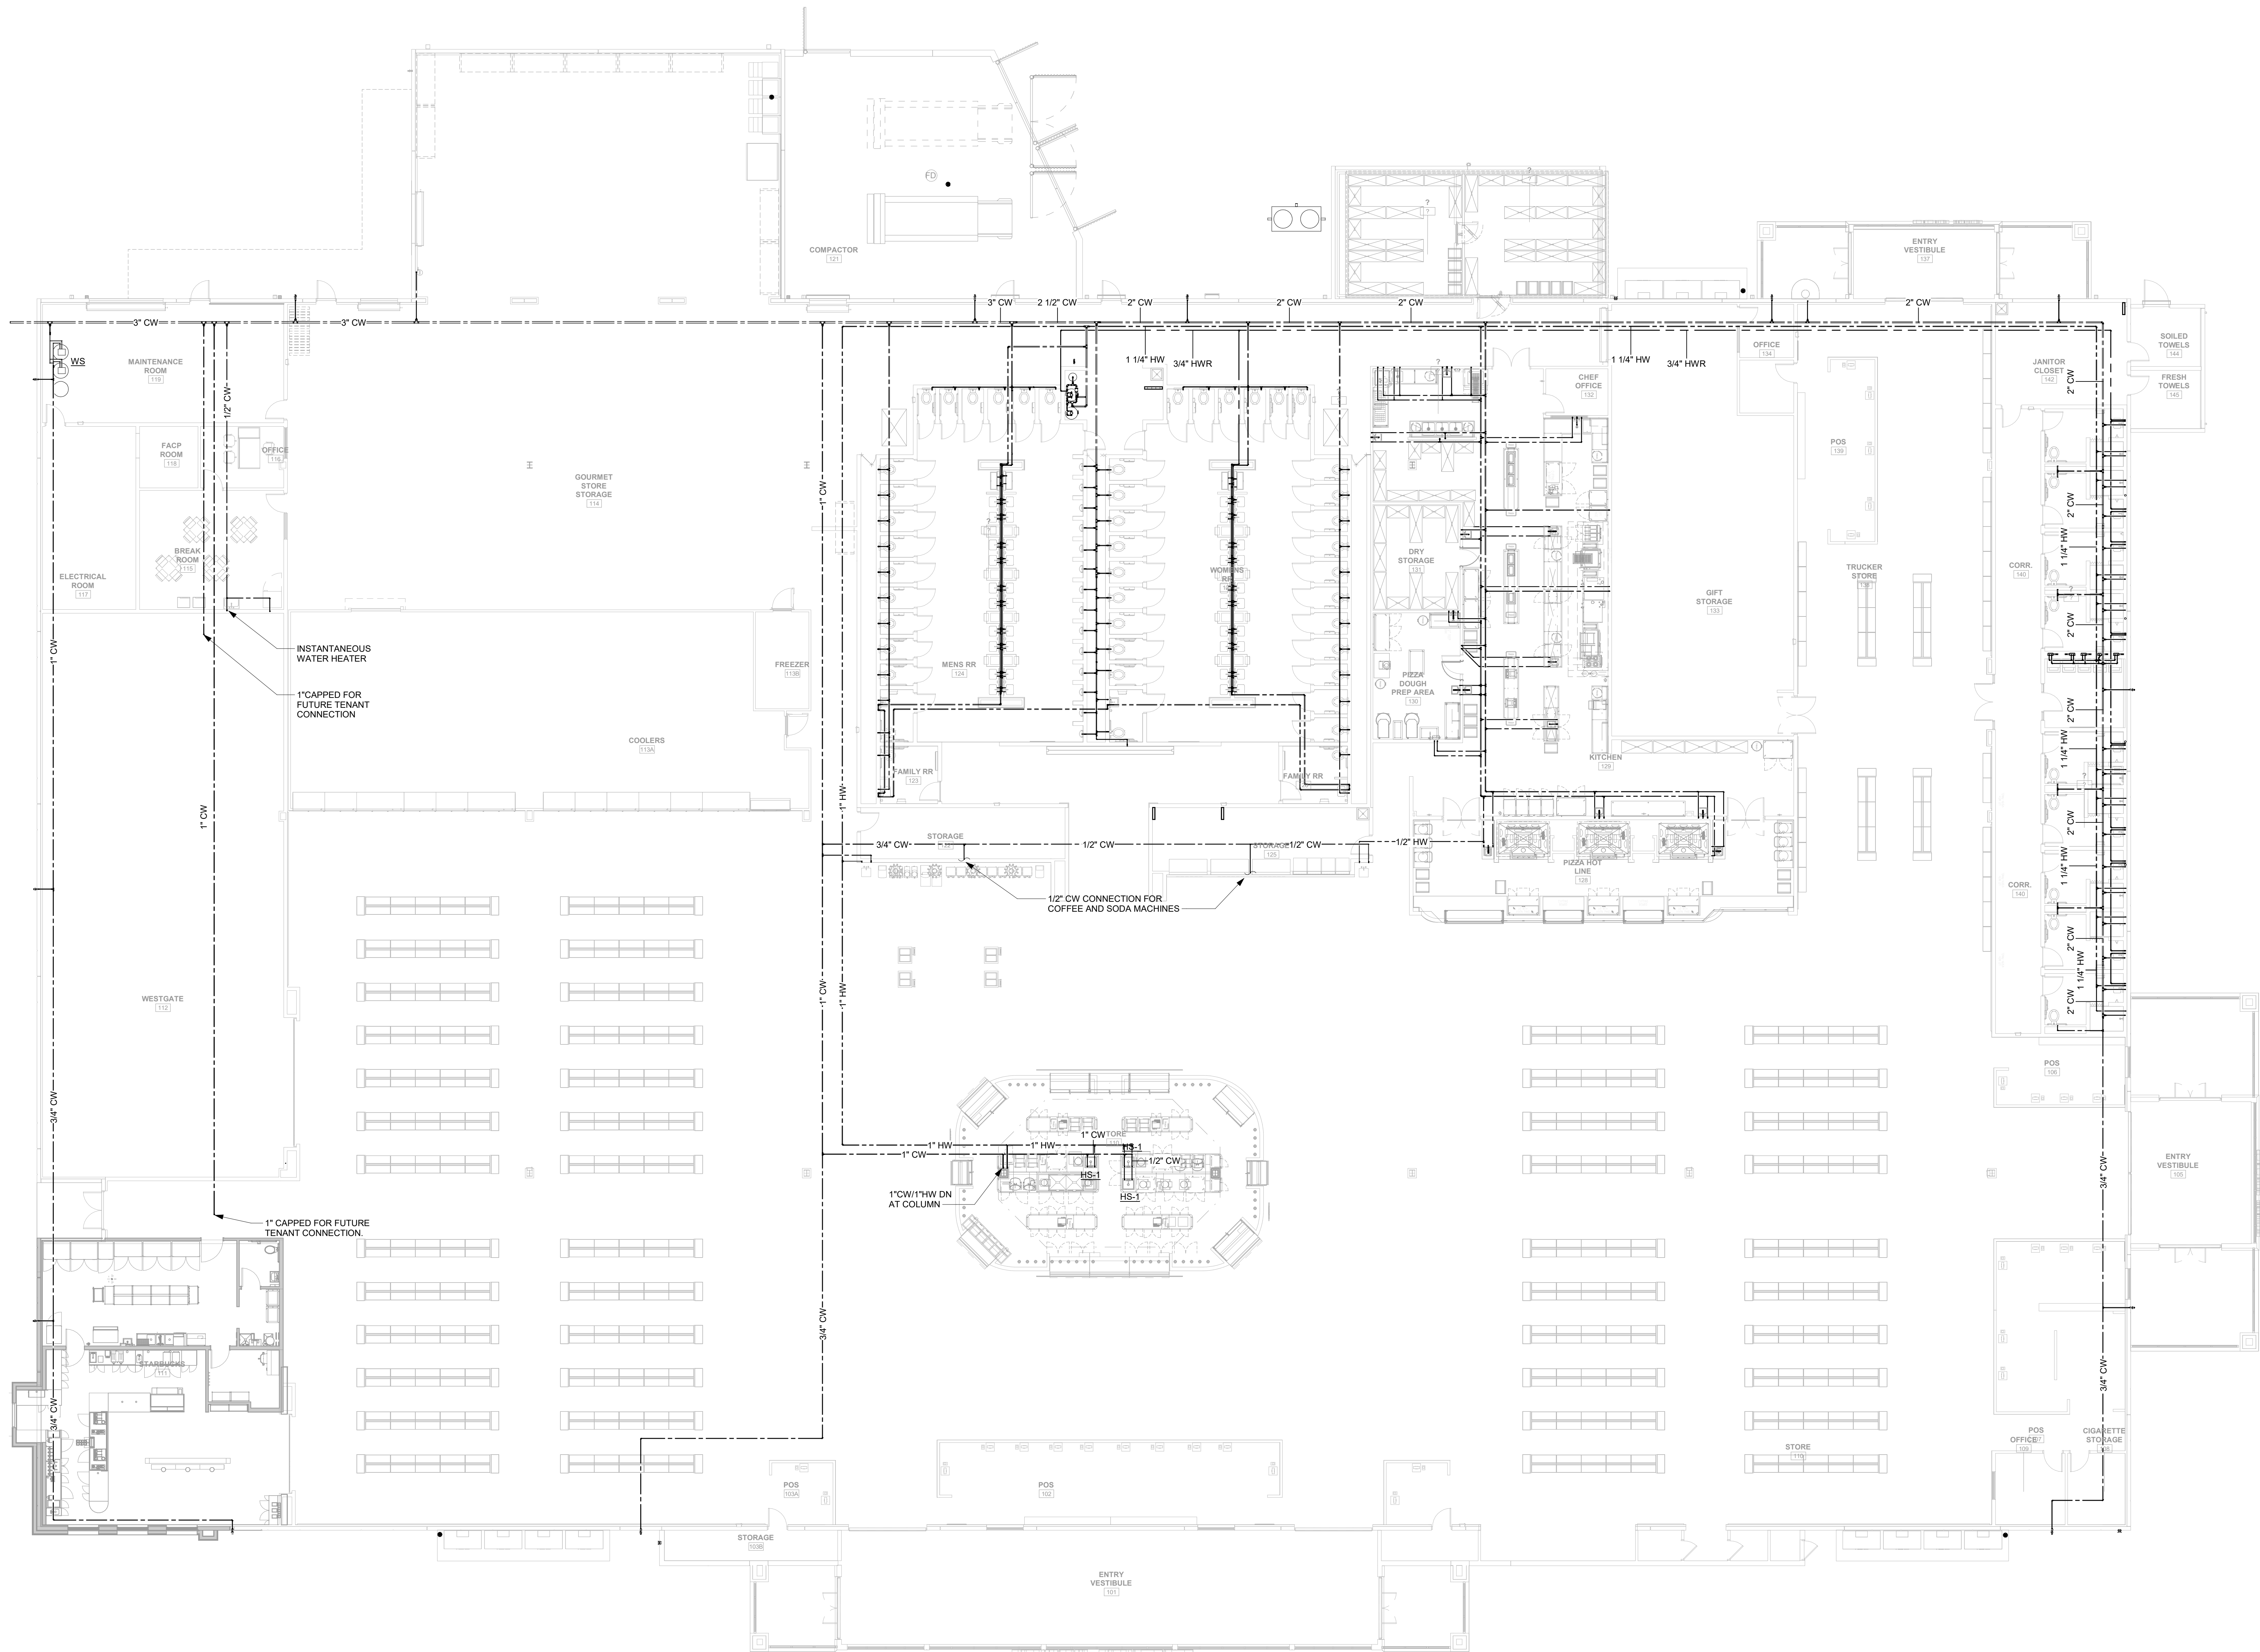


NOT FOR CONSTRUCTION



10175 Fortune Parkway, Suite 701
Jacksonville, FL 32256
p 904.683.9201 f 904.683.9702
www.kasperarch.com
FL License No.: AA2600802



www.IMEGCorp.com
9133 E.G. Shuman Parkway
Jacksonville, Florida 32256
Ph: (904) 483-5700 Fax: (904) 436-0700
email: malhi@McVighMangum.com
CA 6330
Eng. of Record: David D. Dowell
License No.: 78366

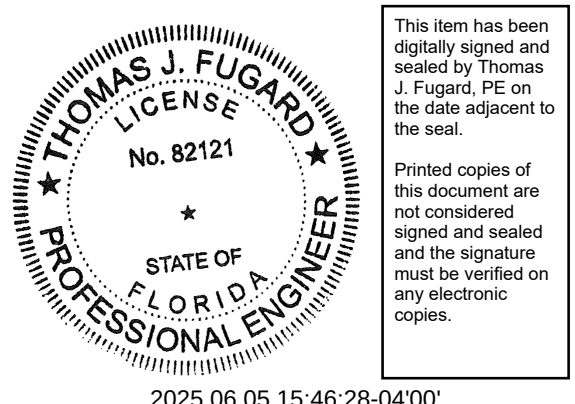

BUSY BEE
ELLISVILLE

136 SW WEBBS GLN
LAKE CITY, FL 32024

PROJECT NO.: 22024

DATE: 04/10/2025

PRIOR ISSUES:


RETAIL STORE
OVERALL DW
FLOOR PLAN

P1.2

DRAWN BY: DD
CHECKED BY: TF

DESIGN DEVELOPMENT

ALL RETAIL, SPECIFICATIONS, COMPUTER FILES, FIELD DATA AND OTHER DOCUMENTATION PREPARED BY KASPER ARCHITECTS & ASSOCIATES, INC. (K&A) IS INSTRUMENTS OF SERVICE SHALL REMAIN THE PROPERTY OF K&A. K&A SHALL RETAIN ALL COMMON LAW, STATUTORY AND OTHER RESERVED RIGHTS, INCLUDING THE COPYRIGHT THEREIN. THIS DRAWING SHALL NEVER BE REPRODUCED IN WHOLE OR IN PART WITHOUT THE EXPRESS WRITTEN PERMISSION OF K&A.

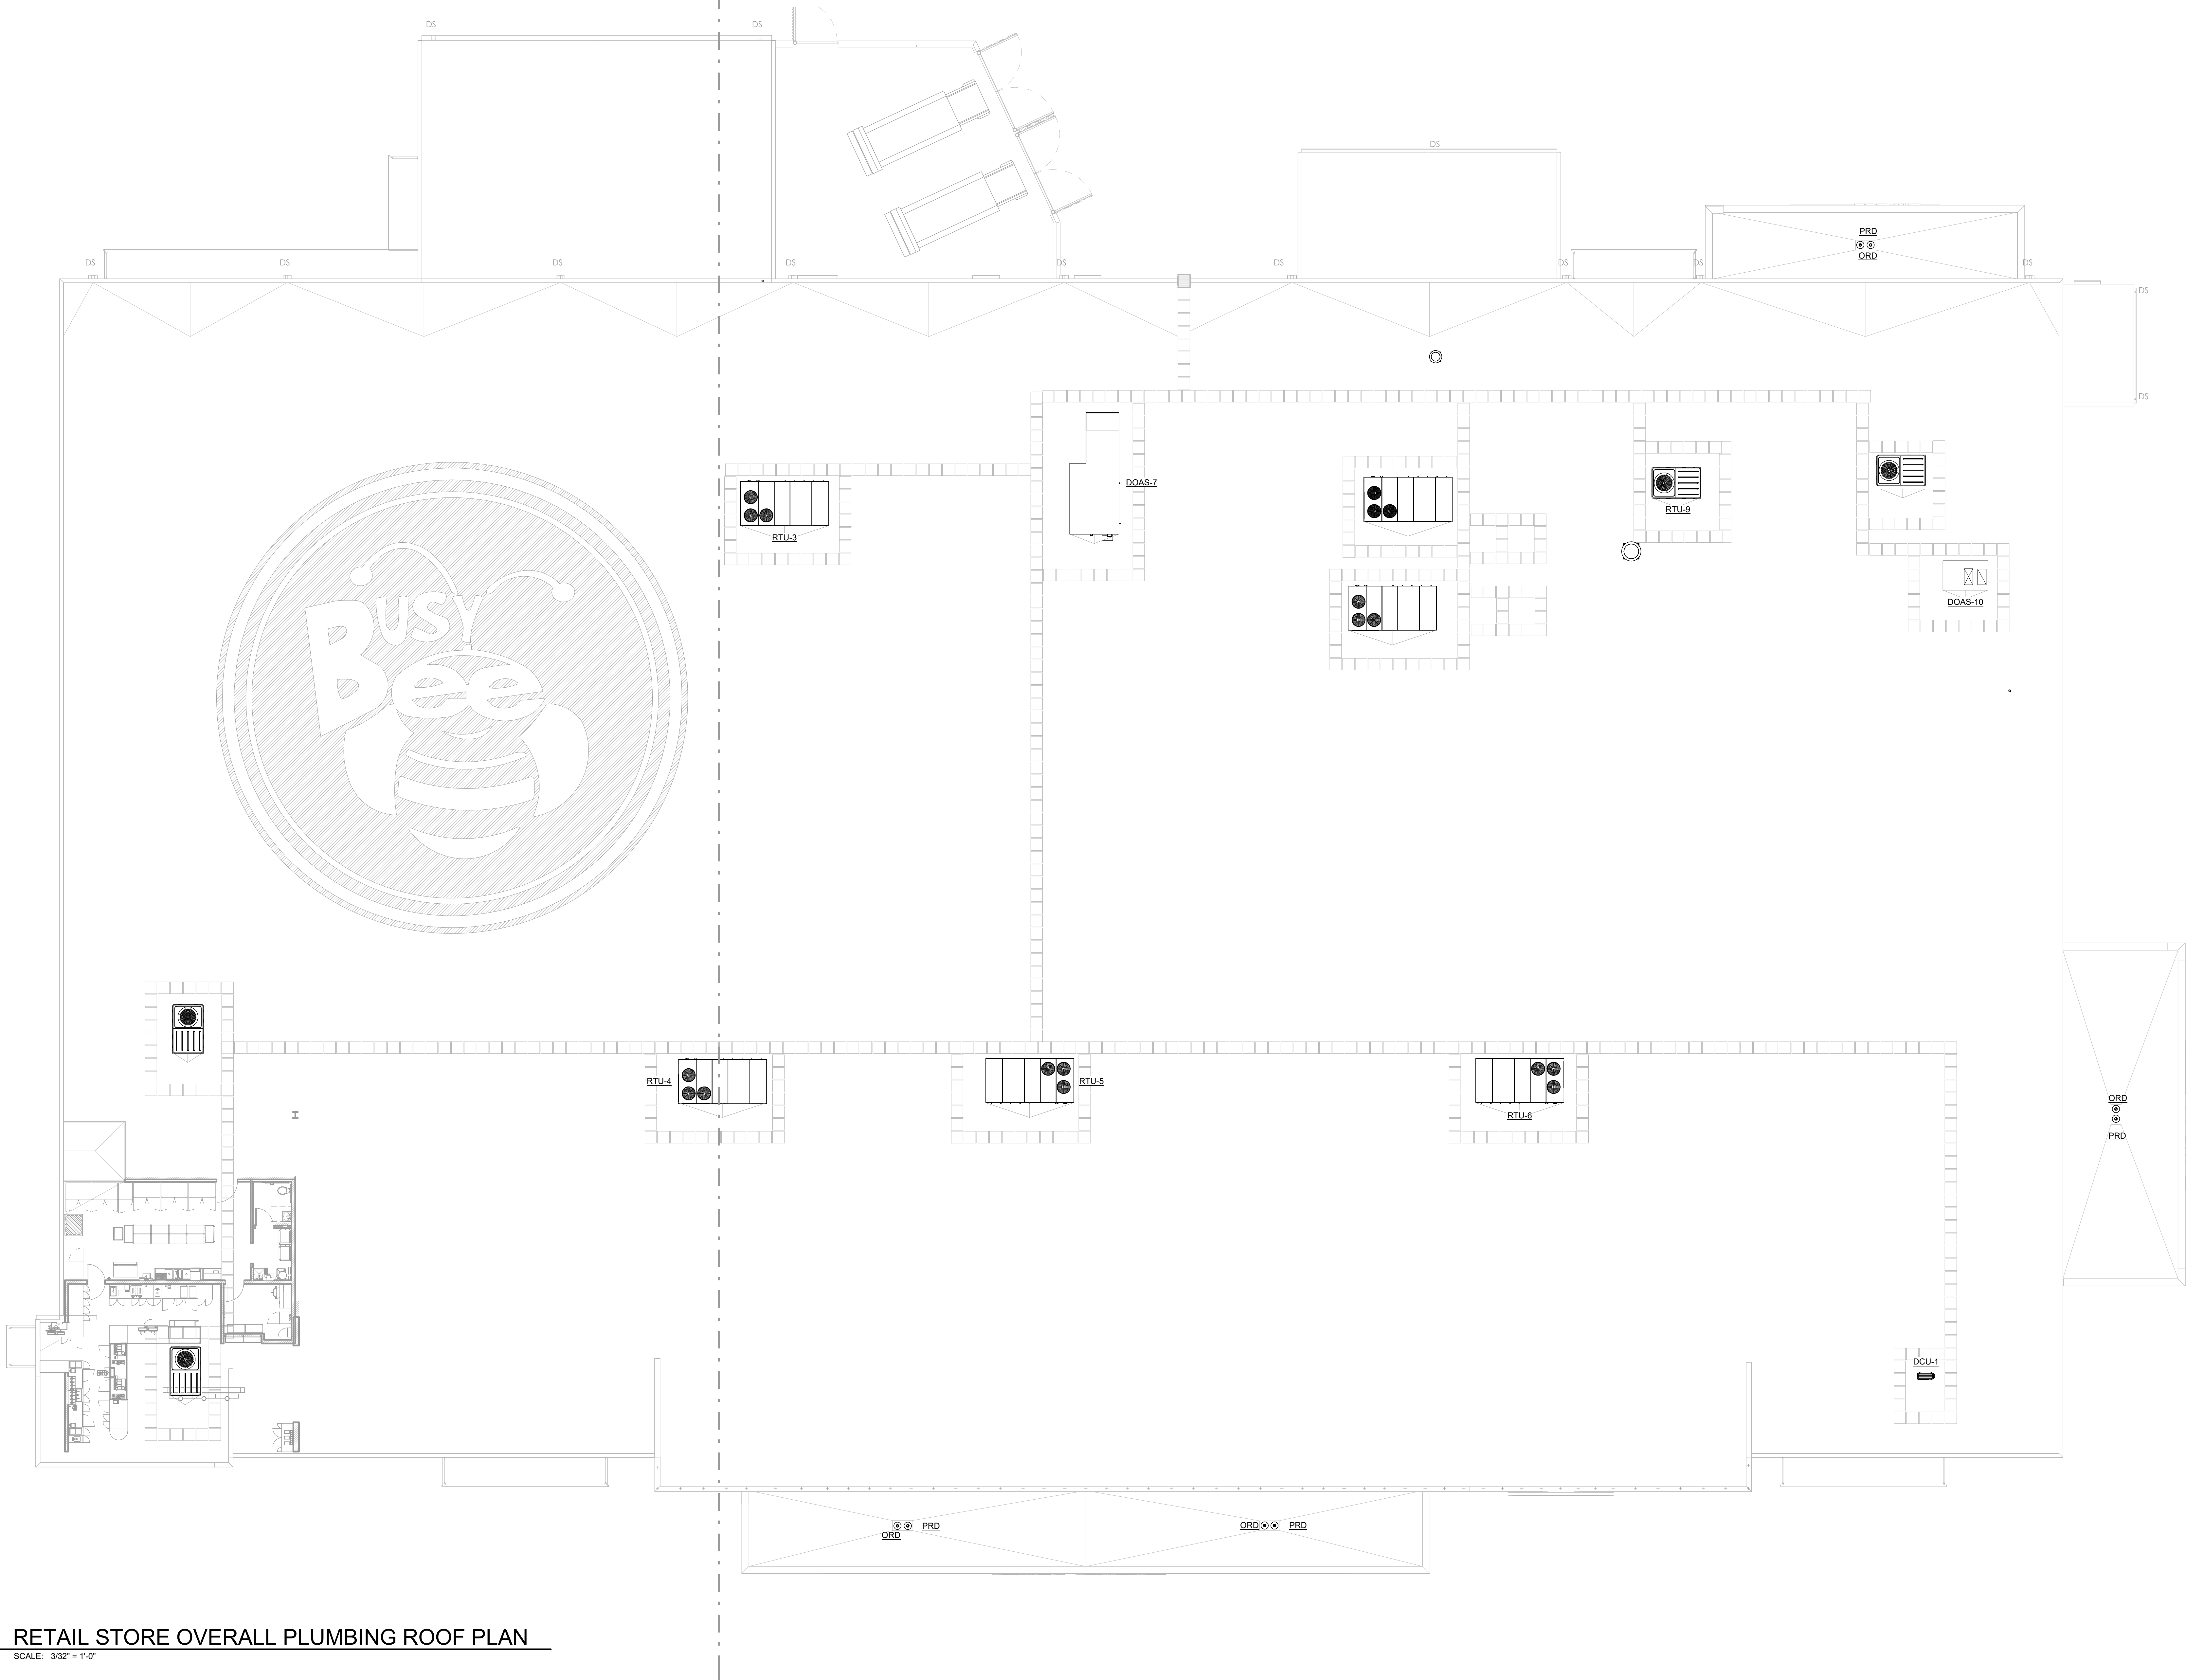


NOT FOR CONSTRUCTION



10175 Fortune Parkway, Suite 701
Jacksonville, FL 32256
p 904.683.9201 f 904.683.9702
www.kasperarch.com
FL License No.: AA2600802



www.IMEGCorp.com
9133 E.G. Silvers Parkway
Jacksonville, Florida 32256
Ph: (904) 483-5200 Fax: (904) 436-6700
email: mah@McVighMangum.com
CA 6330
Eng. of Record
License No.:

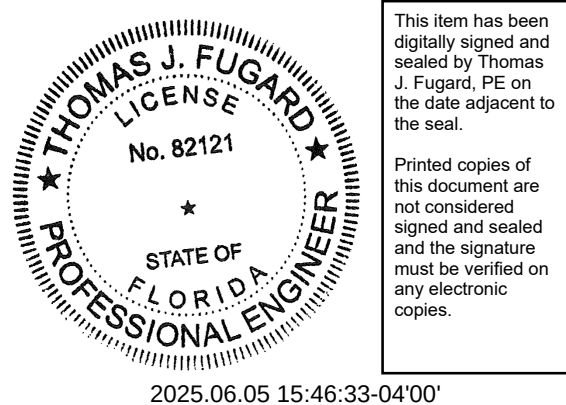

This item has been
digitally signed and
sealed by Thomas
J. Fugard, PE on
the date adjacent to
the seal.
Printed copies of
this document are
not considered
signed and sealed
and the signature
must be verified on
any electronic
copies.

2025.06.05 15:46:33-04'00'

BUSY BEE
ELLISVILLE

136 SW WEBBS GLN
LAKE CITY, FL 32024

PROJECT NO.: 22024

DATE: 04/10/2025

PRIOR ISSUES:

PLUMBING ROOF
PLAN

P2.1

DRAWN BY: DD

CHECKED BY: TF

DESIGN DEVELOPMENT

© 2013

**BUSY BEE
ELLISVILLE**

136 SW WEBBS GLN
LAKE CITY, FL 32024

PROJECT NO.: 22024

DATE: 04/10/2025

PRIOR ISSUES:

**ENLARGED
RESTROOM DWV
PLANS**


P3.1

DRAWN BY: DD

CHECKED BY: TF

DESIGN DEVELOPMENT

NOT FOR CONSTRUCTION

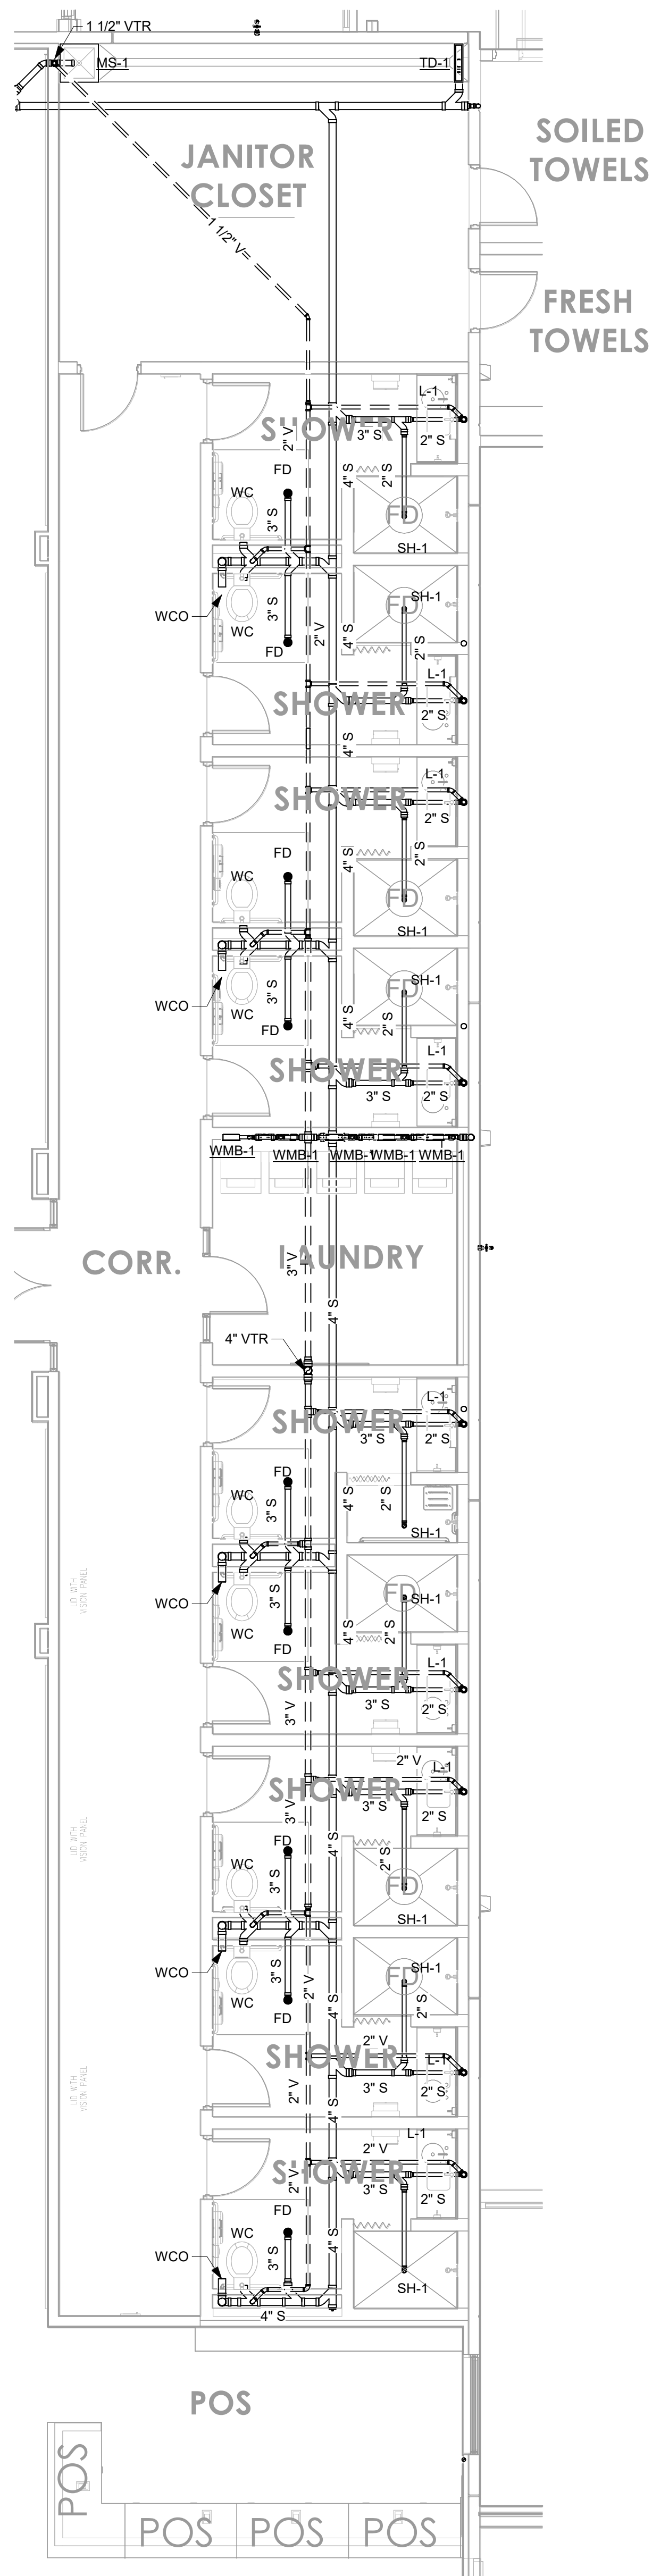




10175 Fortune Parkway, Suite 701
Jacksonville, FL 32256
p 904.683.9201 f 904.683.9702
www.kasperarch.com
FL License No.: AA2600802



www.IMEGCorp.com
9133 E.G. Slosser Parkway
Jacksonville, Florida 32256
Ph: (904) 483-5700 Fax: (904) 436-0700
email: malhi@McVighMangum.com
CA 6330
Eng. of Record: David D. Dowell
License No.: 78366

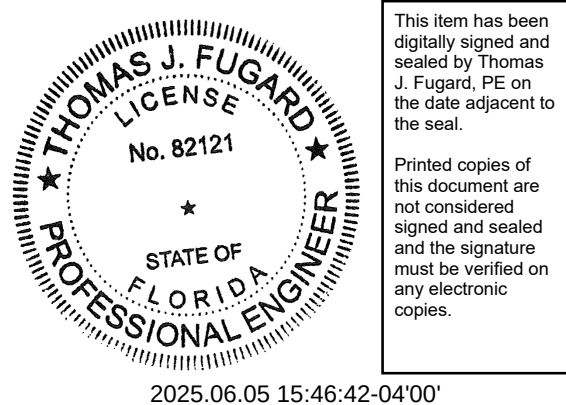

BUSY BEE
ELLISVILLE

136 SW WEBBS GLN
LAKE CITY, FL 32024


PROJECT NO.: 22024
DATE: 04/10/2025
PRIOR ISSUES:

ENLARGED
KITCHEN DWV
PLANS

P3.2

DRAWN BY: DD
CHECKED BY: TF

DESIGN DEVELOPMENT

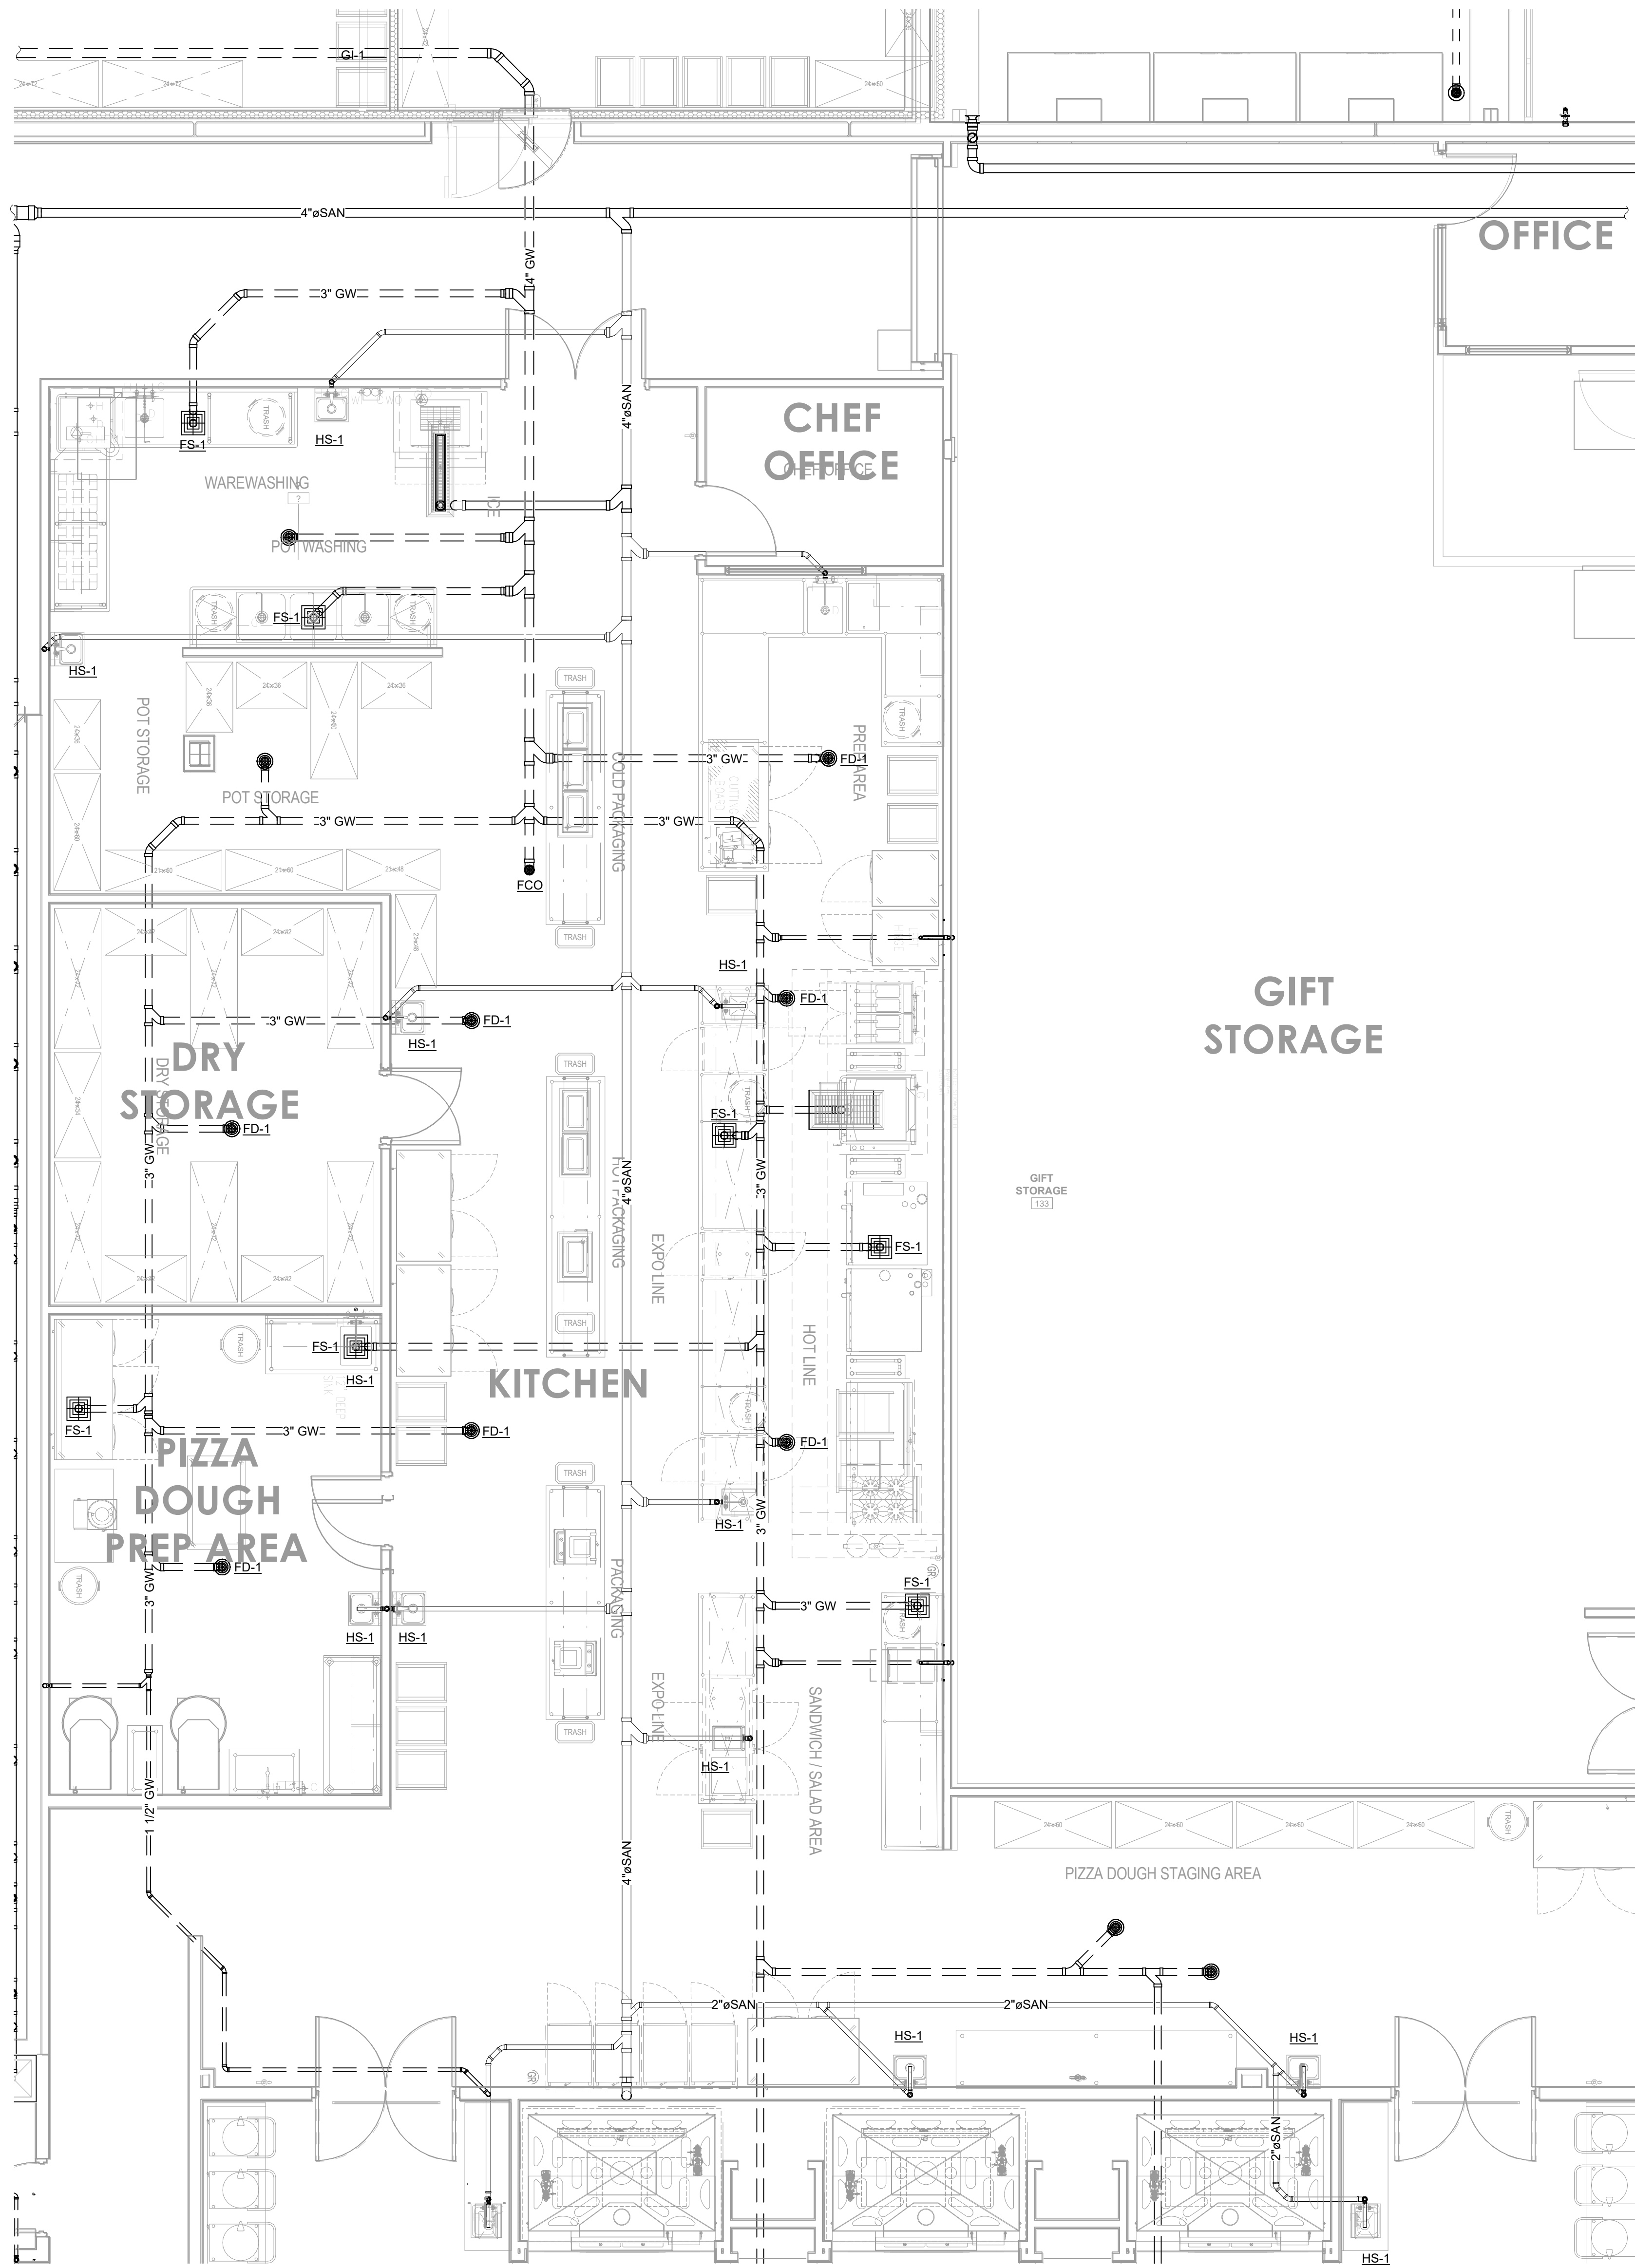

1
P3.2 ENLARGED DWV KITCHEN
SCALE: 1/4" = 1'-0"

NOT FOR CONSTRUCTION


- # KEYED NOTES:
1. 1/2" CW & HW DN.
 2. 1" CW DN.



10175 Fortune Parkway, Suite 701
Jacksonville, FL 32256
p 904.683.9201 f 904.683.9702
www.kasperarch.com
FL License No.: AA2600802



www.IMEGCorp.com
9133 E.G. Slosser Parkway
Jacksonville, Florida 32256
Ph: (904) 483-5700 Fax: (904) 436-0700
email: mahli@McVighMangum.com
CA 6330
Eng. of Record: David D. Dowell
License No.: 78366

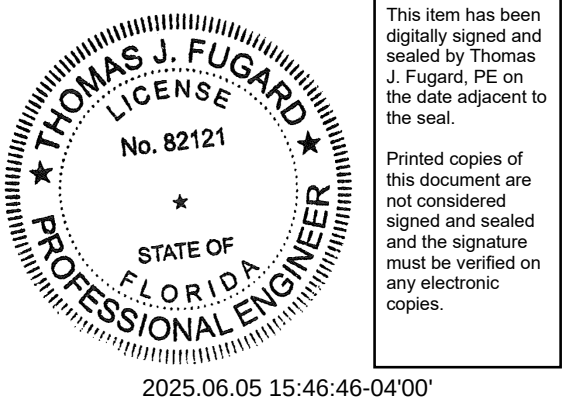

BUSY BEE ELLISVILLE

136 SW WEBBS GLN
LAKE CITY, FL 32024

PROJECT NO.: 22024
DATE: 04/10/2025
PRIOR ISSUES:

ENLARGED RESTROOM DW PLANS


P3.3

DRAWN BY: DD
CHECKED BY: TF


DESIGN DEVELOPMENT

NOT FOR CONSTRUCTION

© 2013

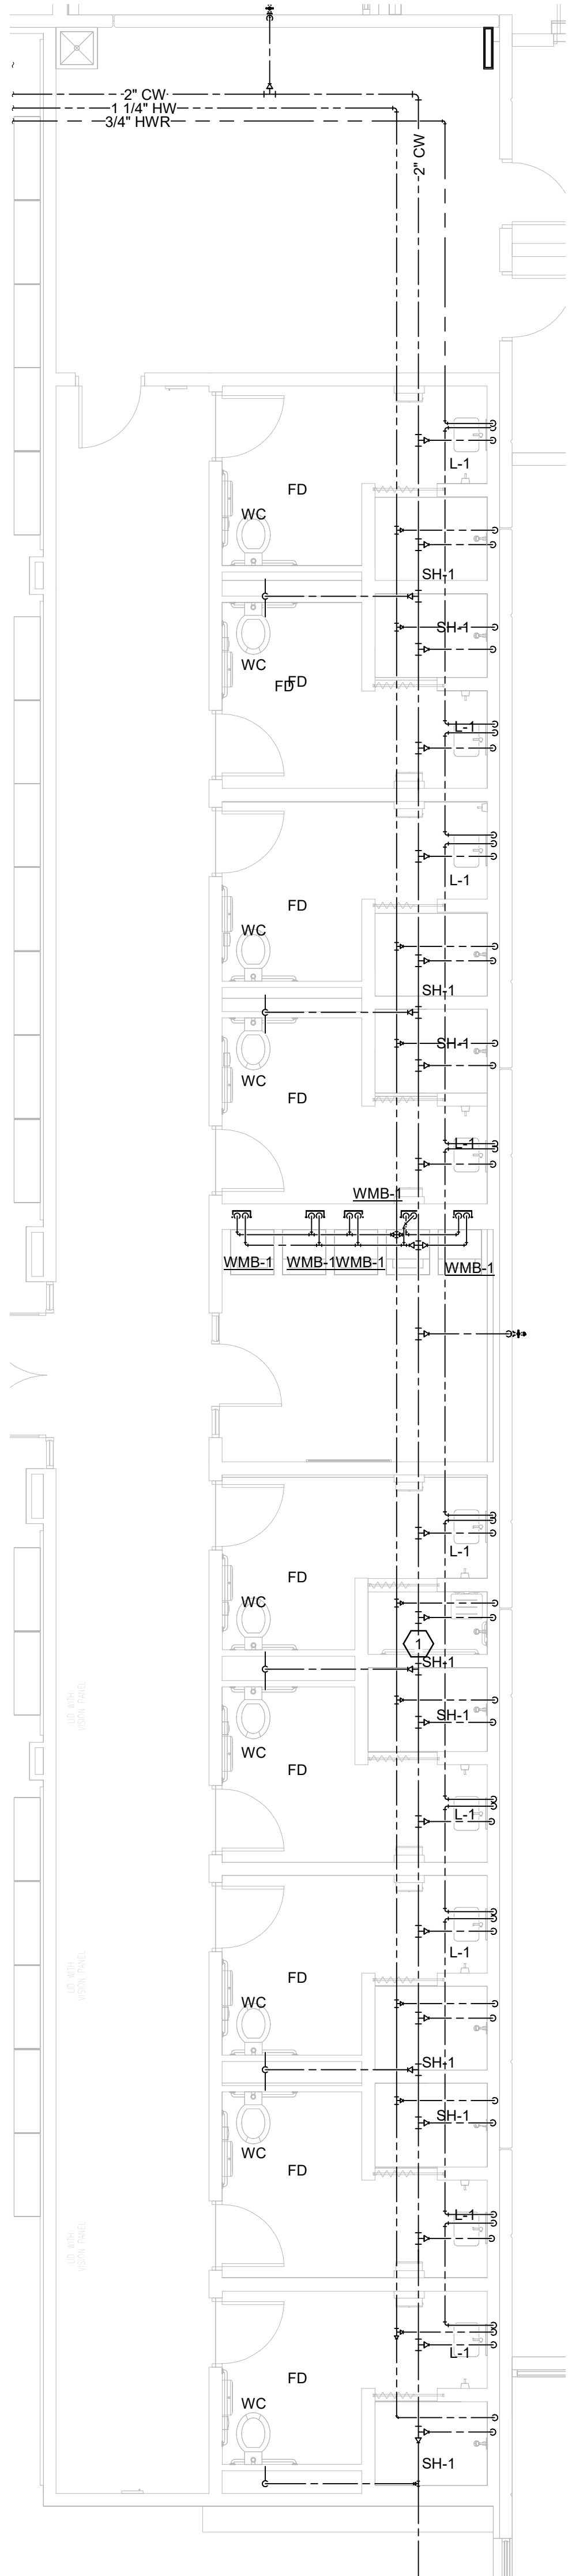


1 ENLARGED DW SHOWERS
P3.3 SCALE: 3/16" = 1'-0"

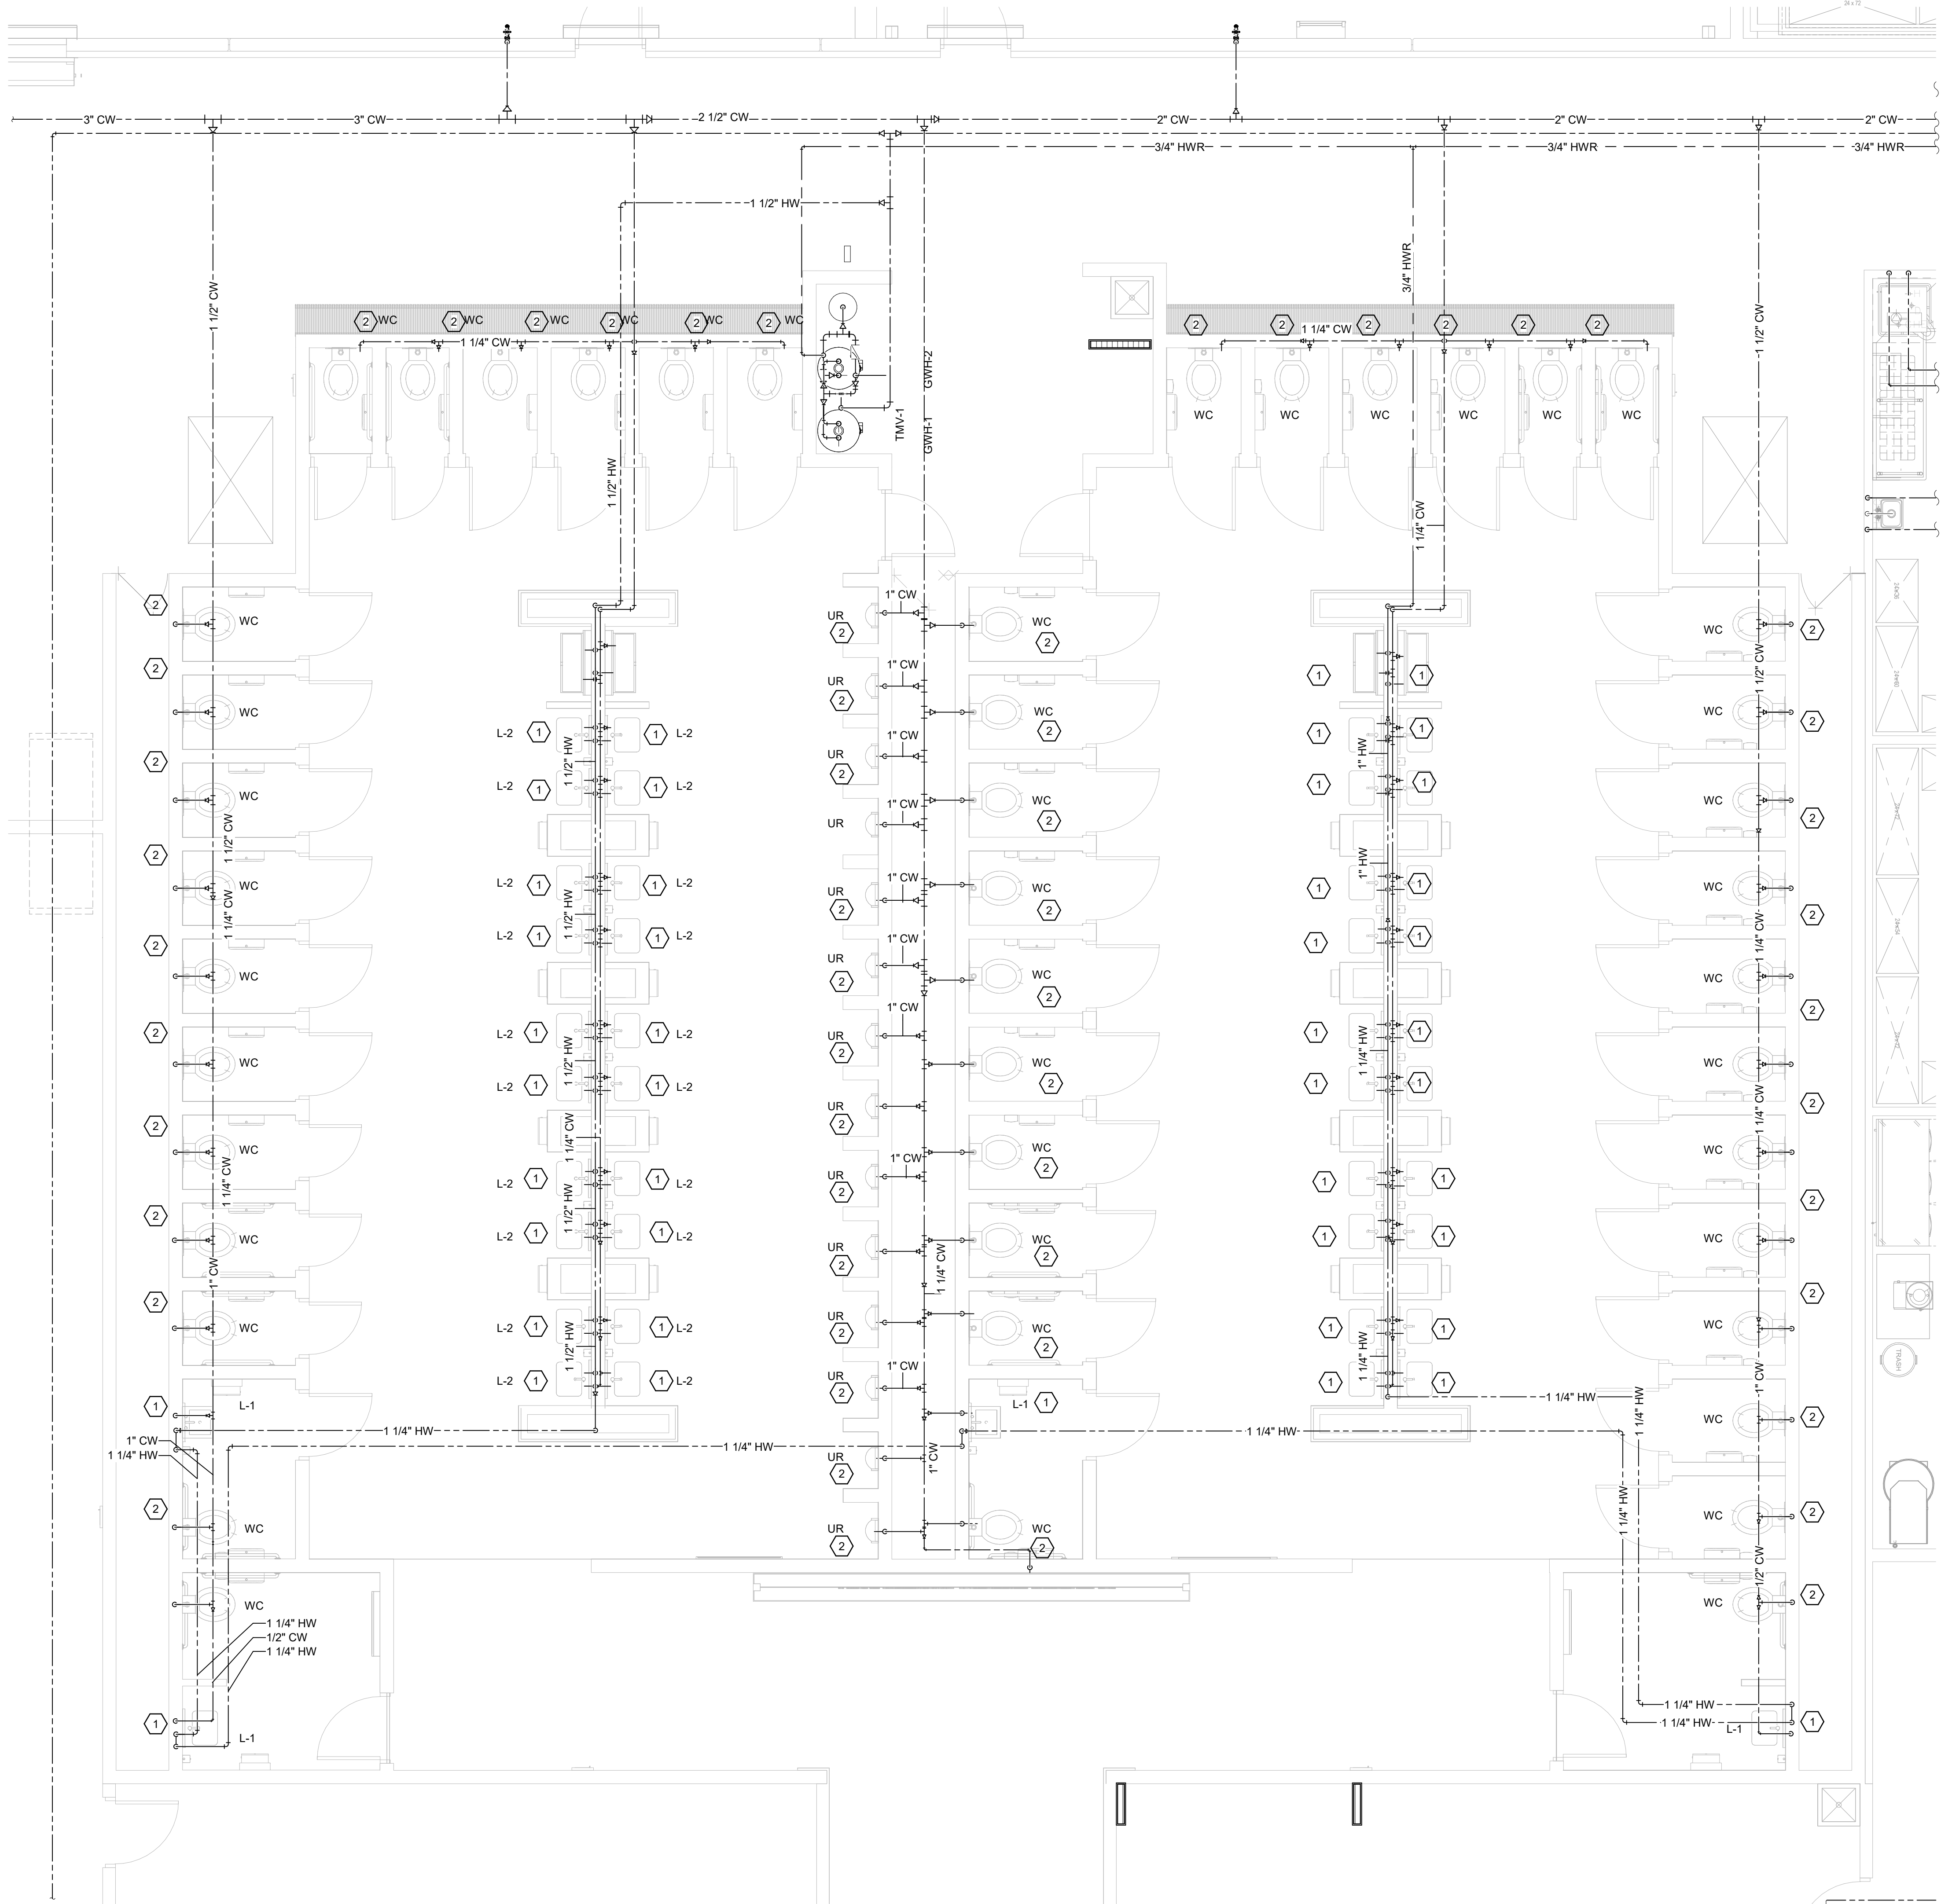

2 ENLARGED DW MENS/WOMENS GANG RESTROOM
P3.3 SCALE: 1/4" = 1'-0"

ALL REDLINES, SPECIFICATIONS, COMPUTER FILES, FIELD DATA AND OTHER DOCUMENTATION PREPARED BY KASPER ARCHITECTURE & DEVELOPMENT, INC. (KAD) AND INSTRUMENTS OF SERVICE SHALL REMAIN THE PROPERTY OF KAD. KAD SHALL RETAIN ALL COMMON LAW, STATUTORY AND OTHER RESERVED RIGHTS, INCLUDING THE COPYRIGHT THEREIN. THIS DRAWING SHALL NOT BE REPRODUCED IN WHOLE OR IN PART WITHOUT THE EXPRESS WRITTEN PERMISSION OF KAD.

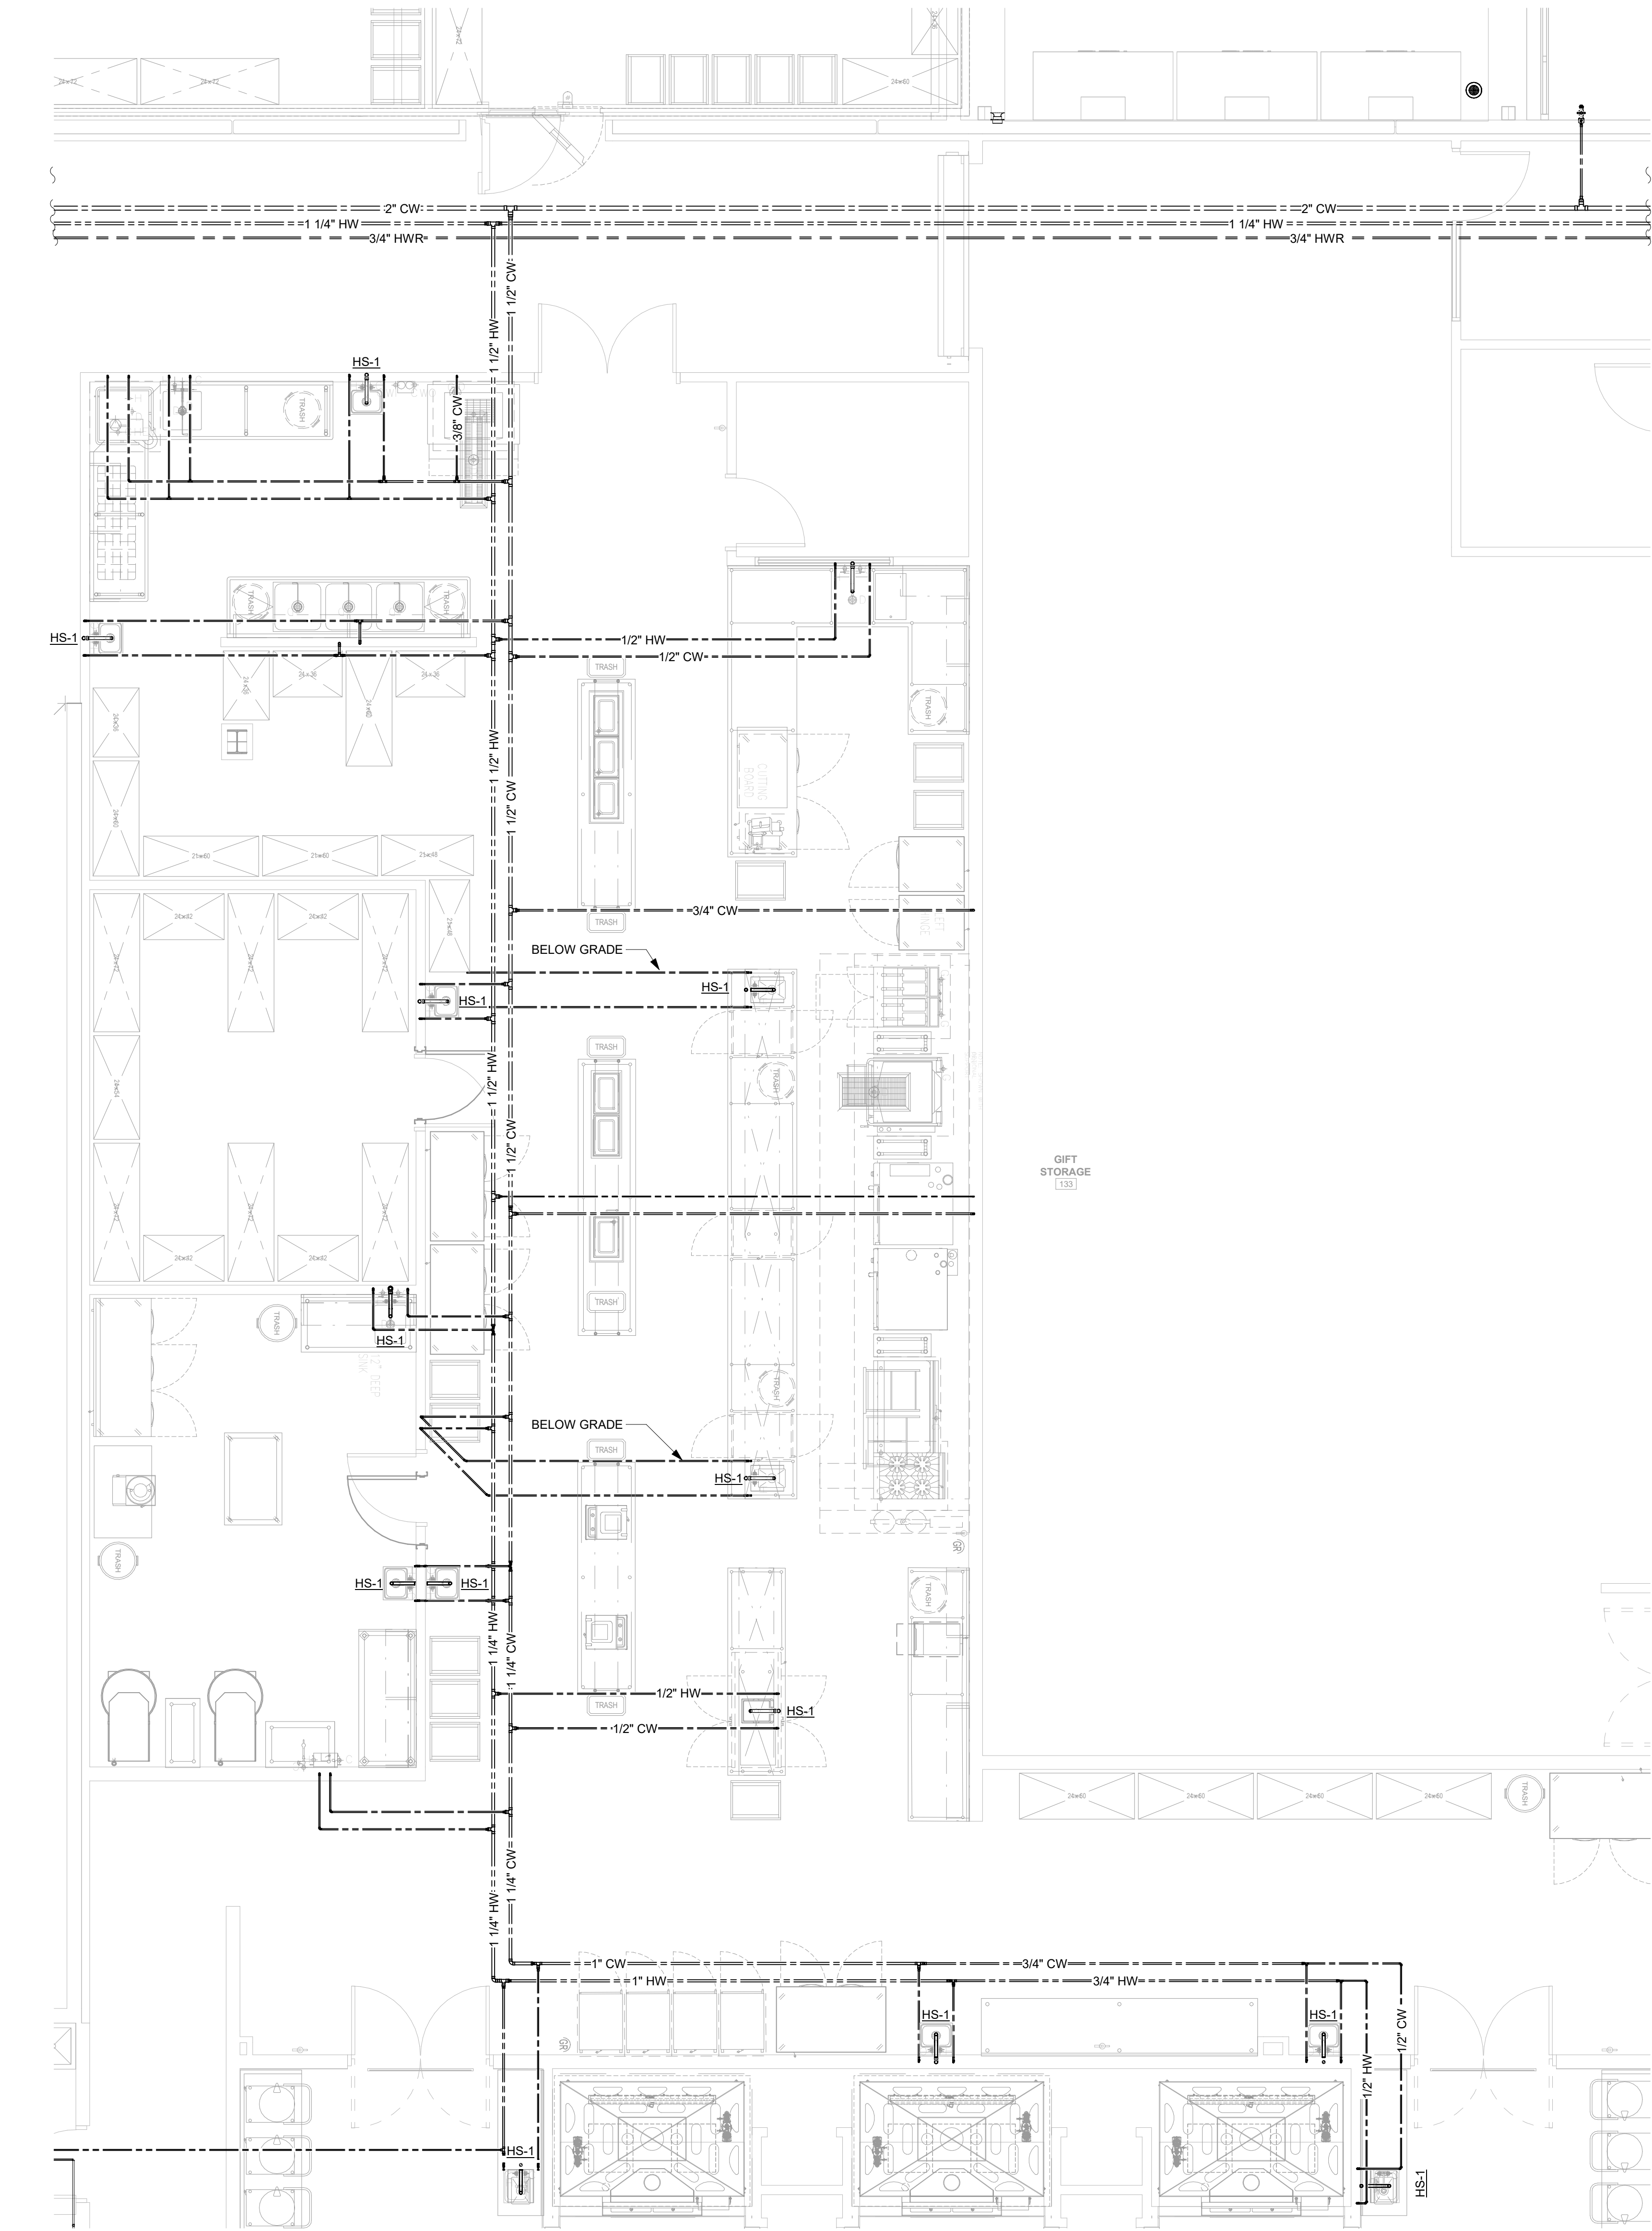

1
P3.4
ENLARGED DW KITCHEN
SCALE: 1/4" = 1'-0"


NOT FOR CONSTRUCTION



10175 Fortune Parkway, Suite 701
Jacksonville, FL 32256
p 904.683.9201 f 904.683.9702
www.kasperarch.com
FL License No.: AA2600802



formerly McVeigh & Mangum Engineering
www.IMEGCorp.com
9133 E.G. Sasser Parkway
Jacksonville, Florida 32256
Ph: (904) 483-5200 Fax: (904) 636-6700
email: mail@McVeighMangum.com
CA 6330
Eng. of Record: David D. Dowell
License No.: 78366

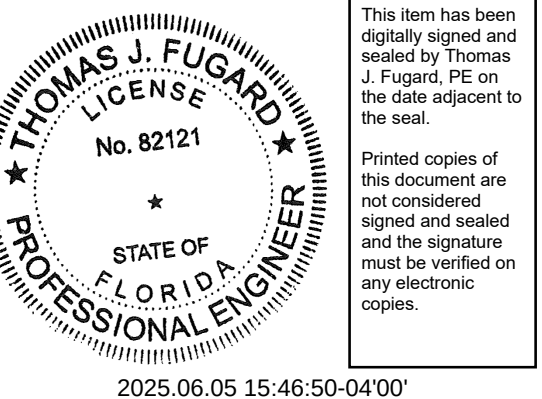

BUSY BEE ELLISVILLE

136 SW WEBBS GLN
LAKE CITY, FL 32024

PROJECT NO.: 22024
DATE: 04/10/2025
PRIOR ISSUES:

ENLARGED KITCHEN DW PLANS

P3.4

DRAWN BY: DD
CHECKED BY: TF


DESIGN DEVELOPMENT



10175 Fortune Parkway, Suite 701
Jacksonville, FL 32256
p 904.683.9201 f 904.683.9702
www.kasperarch.com
FL License No.: AA2600802



www.IMEGCorp.com
9133 R.G. Shuman Parkway
Jacksonville, Florida 32256
Ph: (904) 483-5200 Fax: (904) 636-0700
email: malhi@McVeighMangum.com
CA 6830
Eng. of Record: David D. Dowell
License No.: 78366

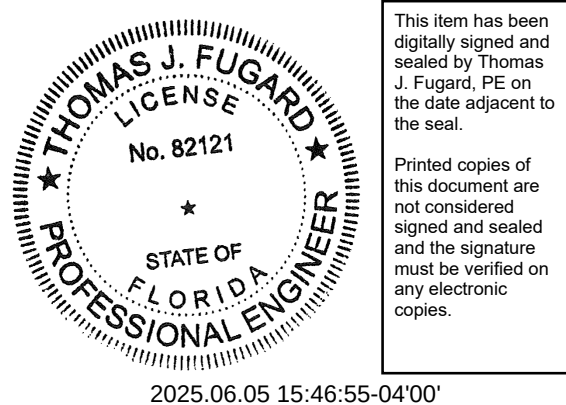

BUSY BEE ELLISVILLE

136 SW WEBBS GLN
LAKE CITY, FL 32024

PROJECT NO.: 22024
DATE: 04/10/2025
PRIOR ISSUES:


ENLARGED CENTER STAGE DWV PLANS

P3.5

DRAWN BY: DD
CHECKED BY: TF


DESIGN DEVELOPMENT

NOT FOR CONSTRUCTION

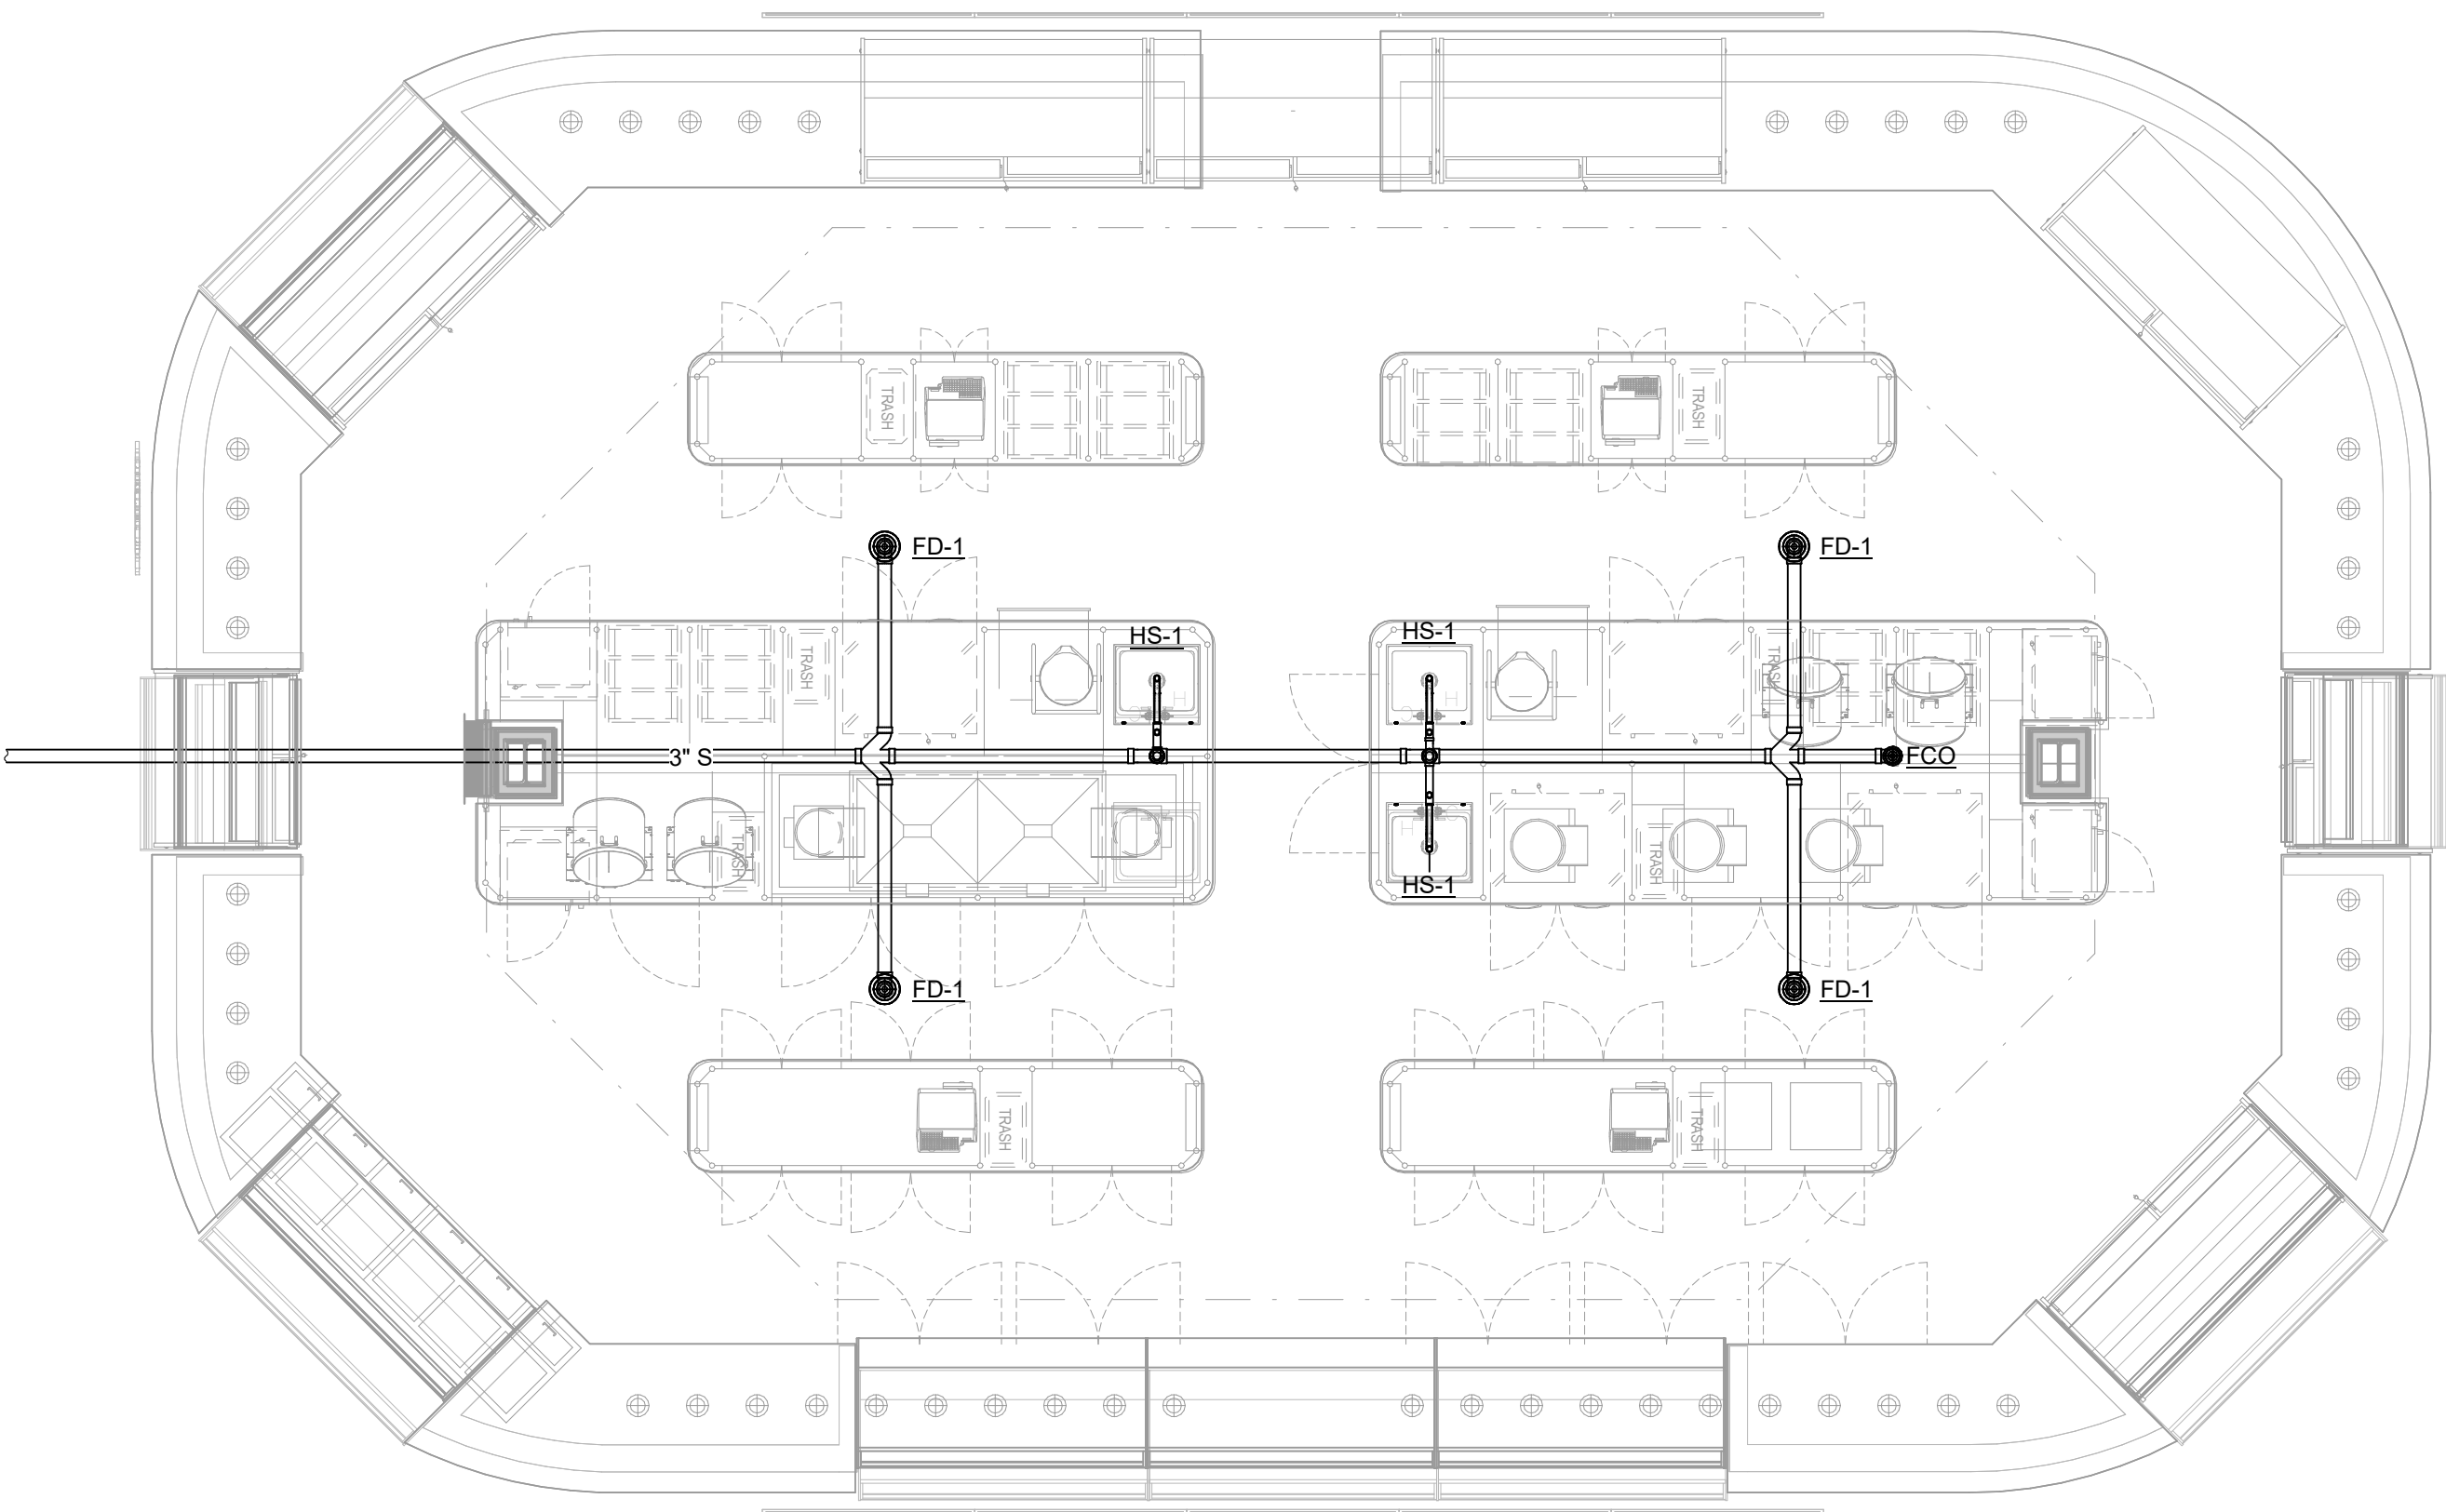

1
P3.5
ENLARGED DWV CENTER STAGE
SCALE: 1/4" = 1'-0"

STORE

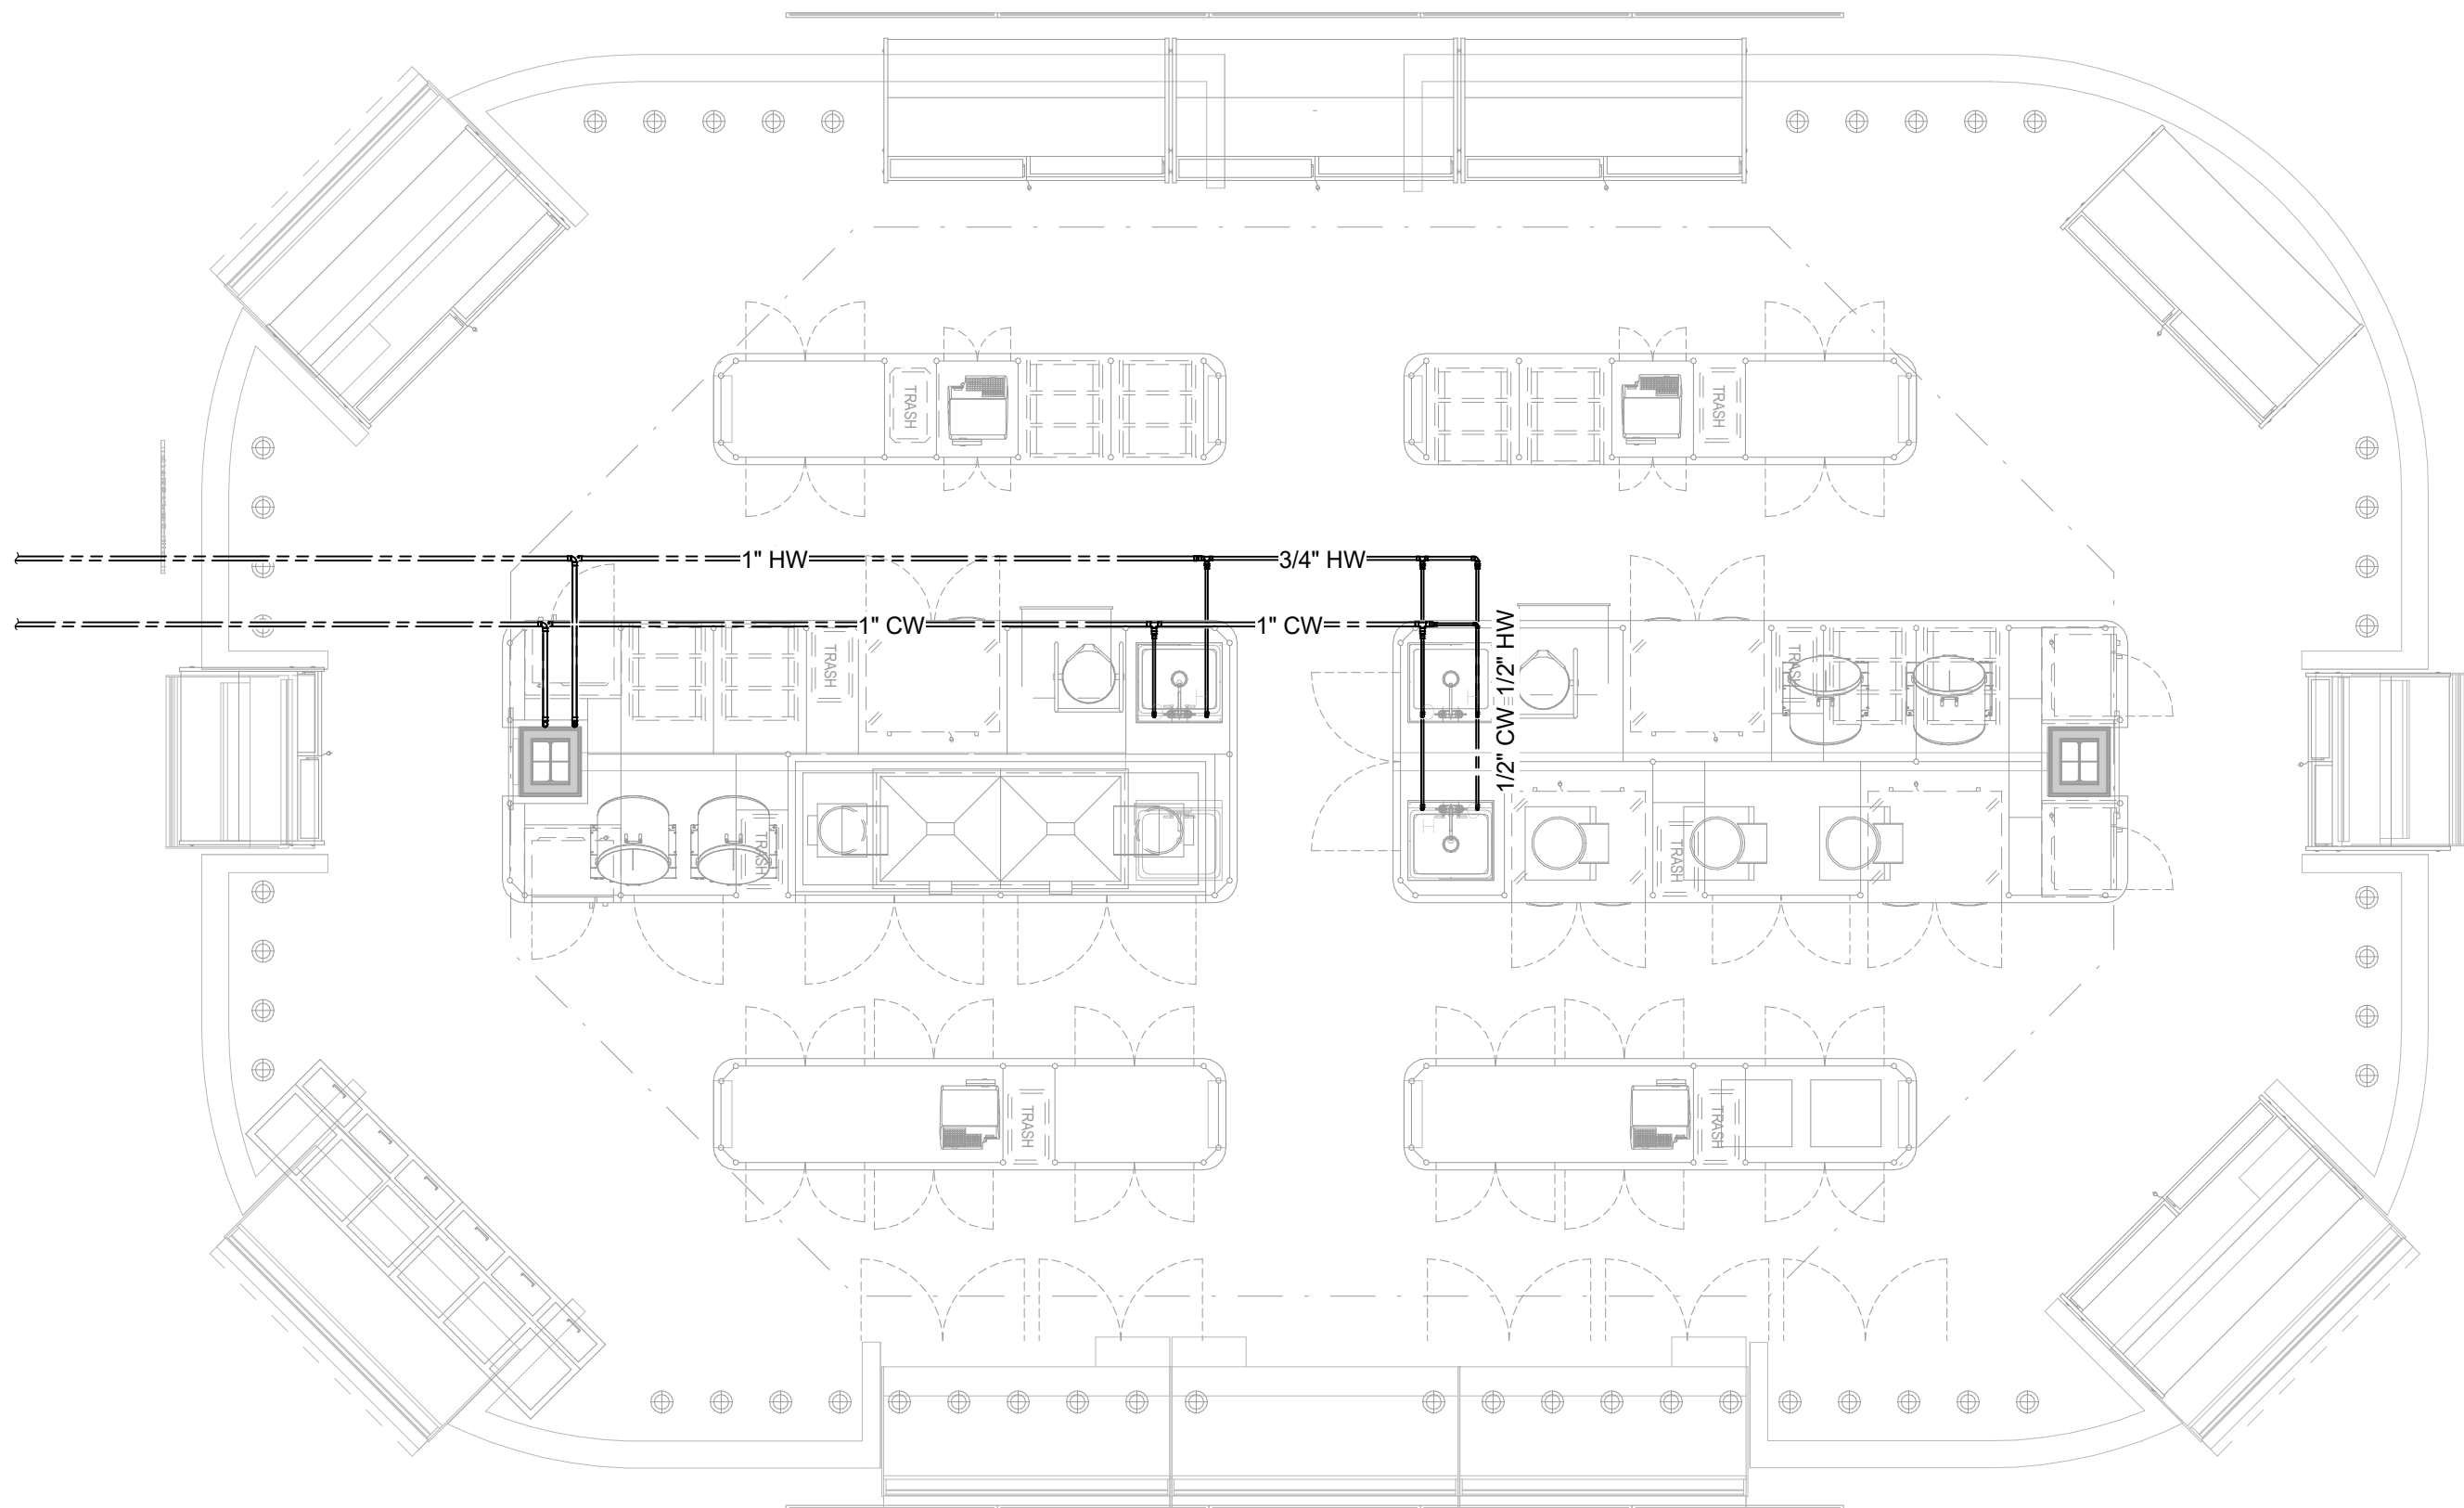

2
P3.5
ENLARGED DW CENTER STAGE
SCALE: 1/4" = 1'-0"

**BUSY BEE
ELLISVILLE**

136 SW WEBBS GLN
LAKE CITY, FL 32024

PROJECT NO.: 22024

DATE: 04/10/2025


PRIOR ISSUES:

**RISER DIAGRAMS
DWV**

P5.1

DRAWN BY: DD
CHECKED BY: TF

DESIGN DEVELOPMENT

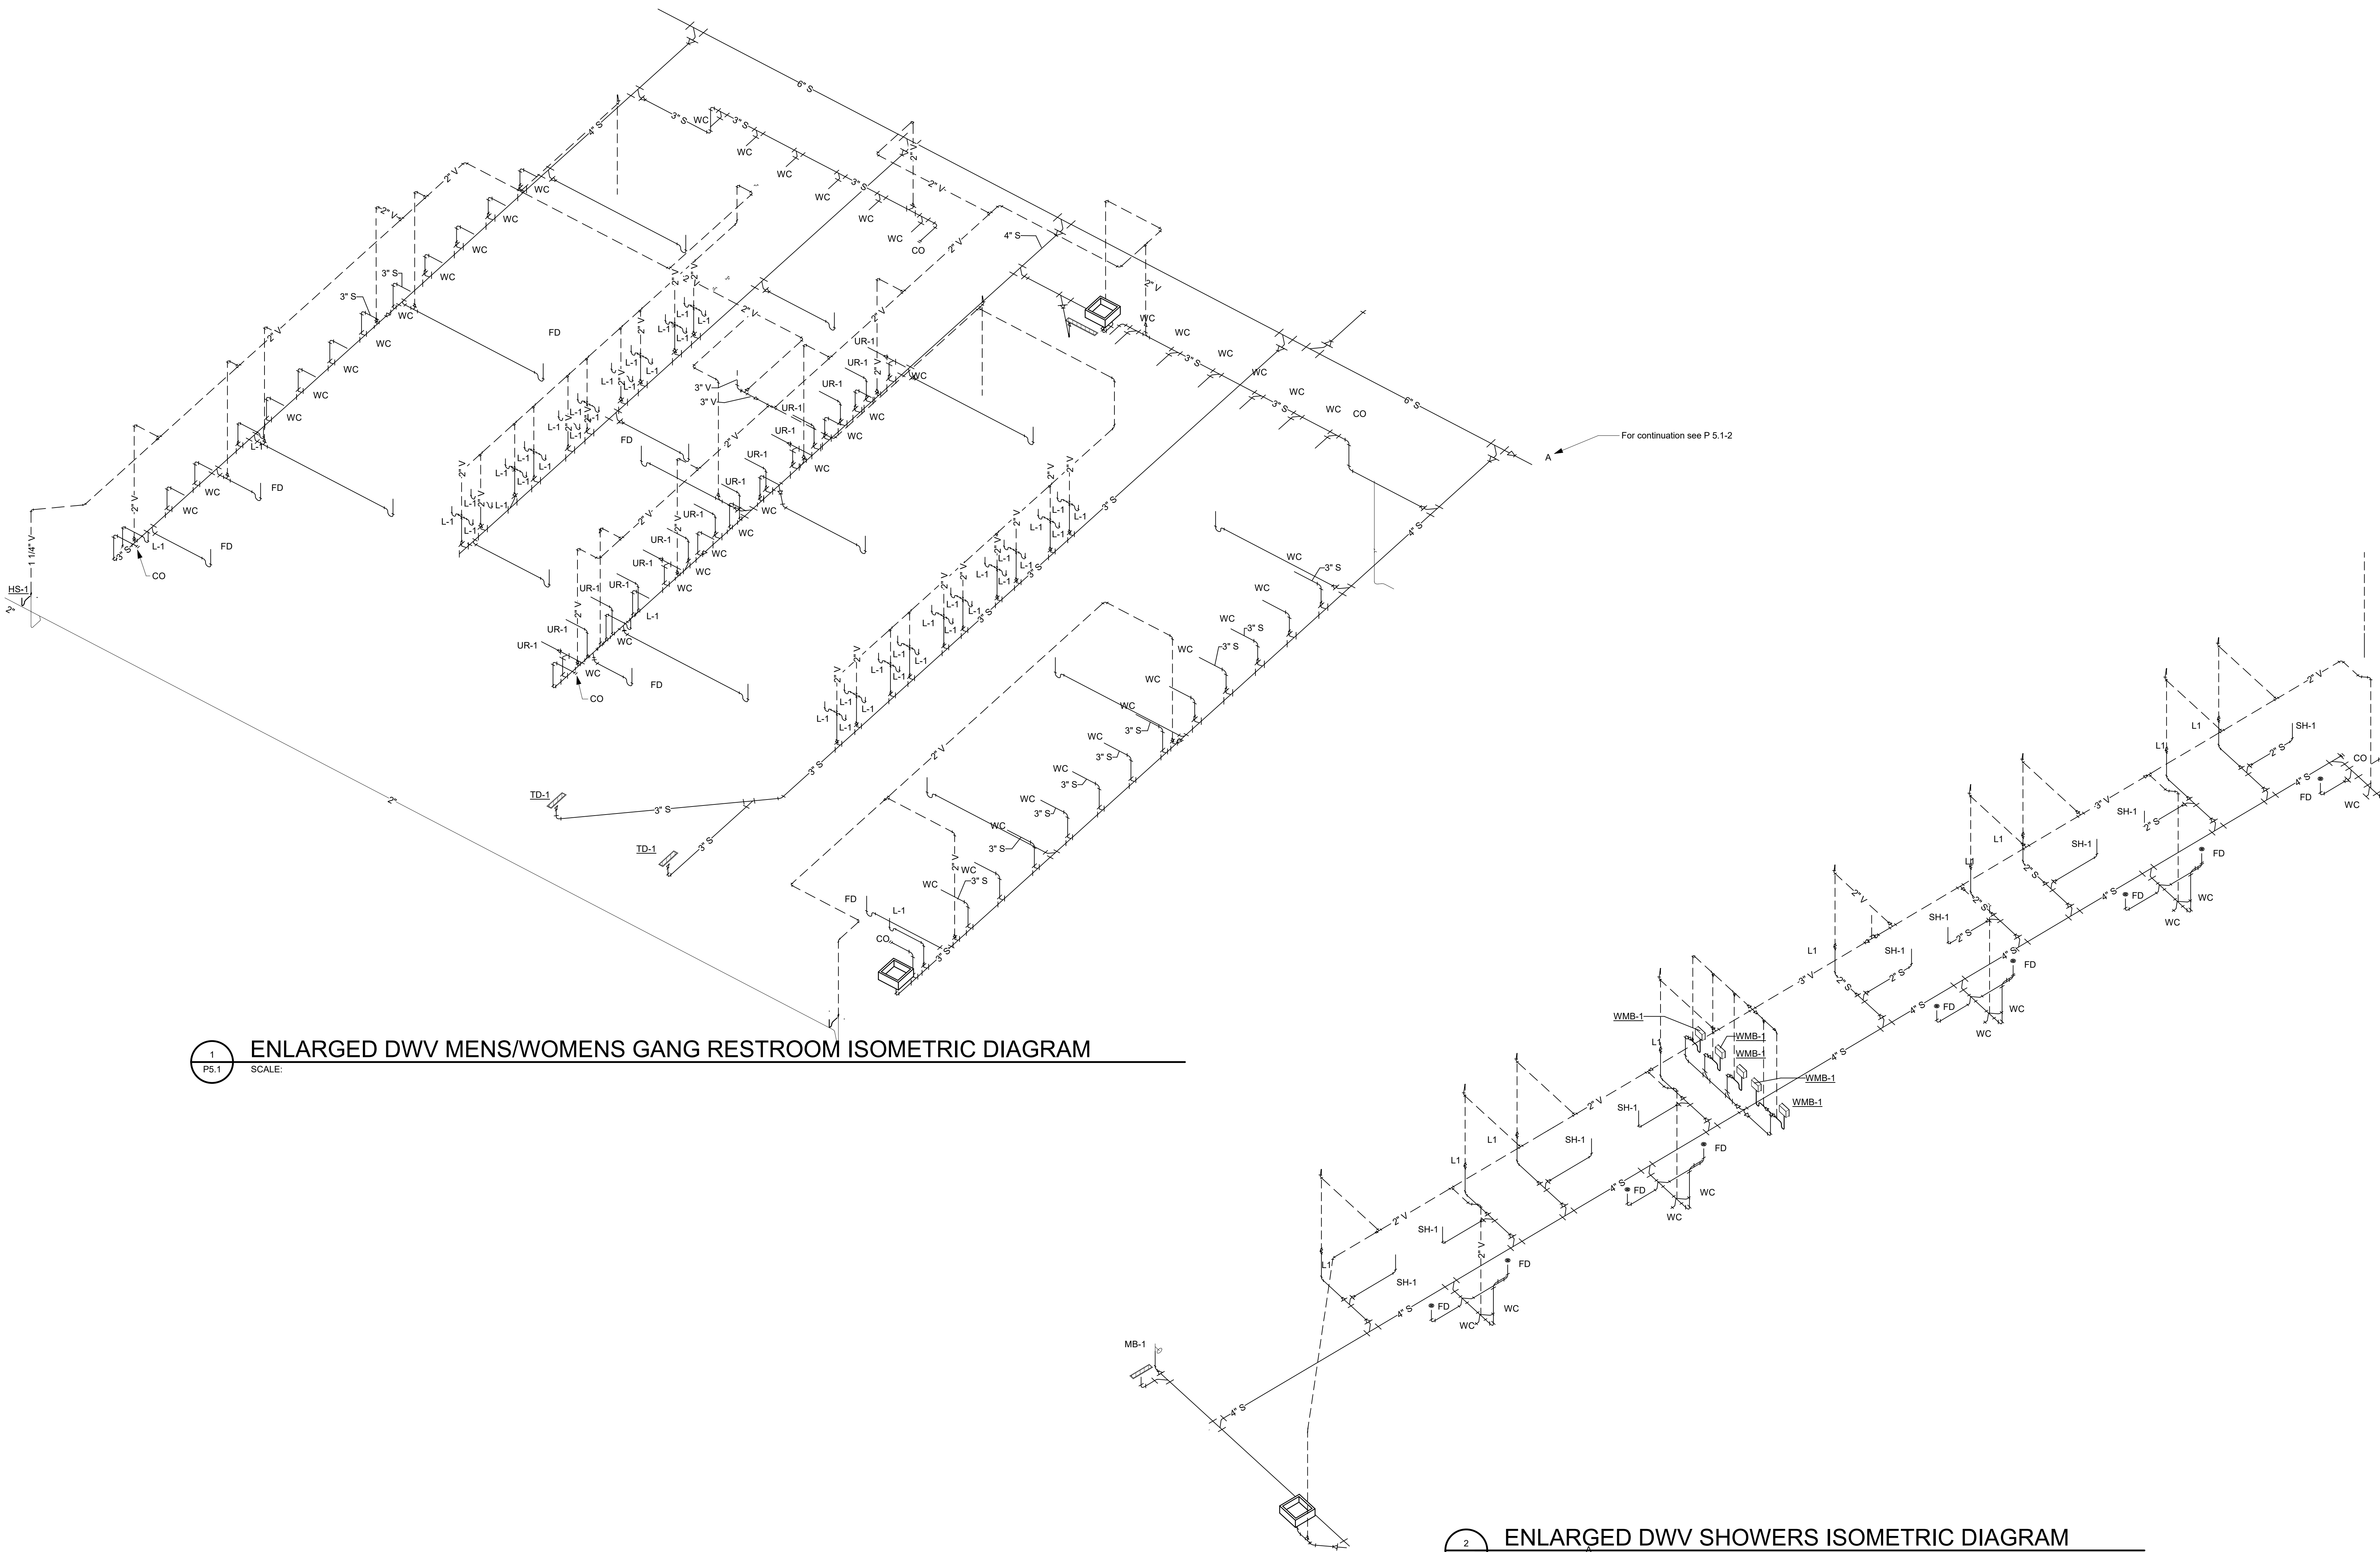

BUSY BEE
ELLISVILLE

136 SW WEBBS GLN
LAKE CITY, FL 32024


PROJECT NO.: 22024
DATE: 04/10/2025
PRIOR ISSUES:

RISER DIAGRAMS
DW

P5.2










DRAWN BY: DD
CHECKED BY: TF

DESIGN DEVELOPMENT

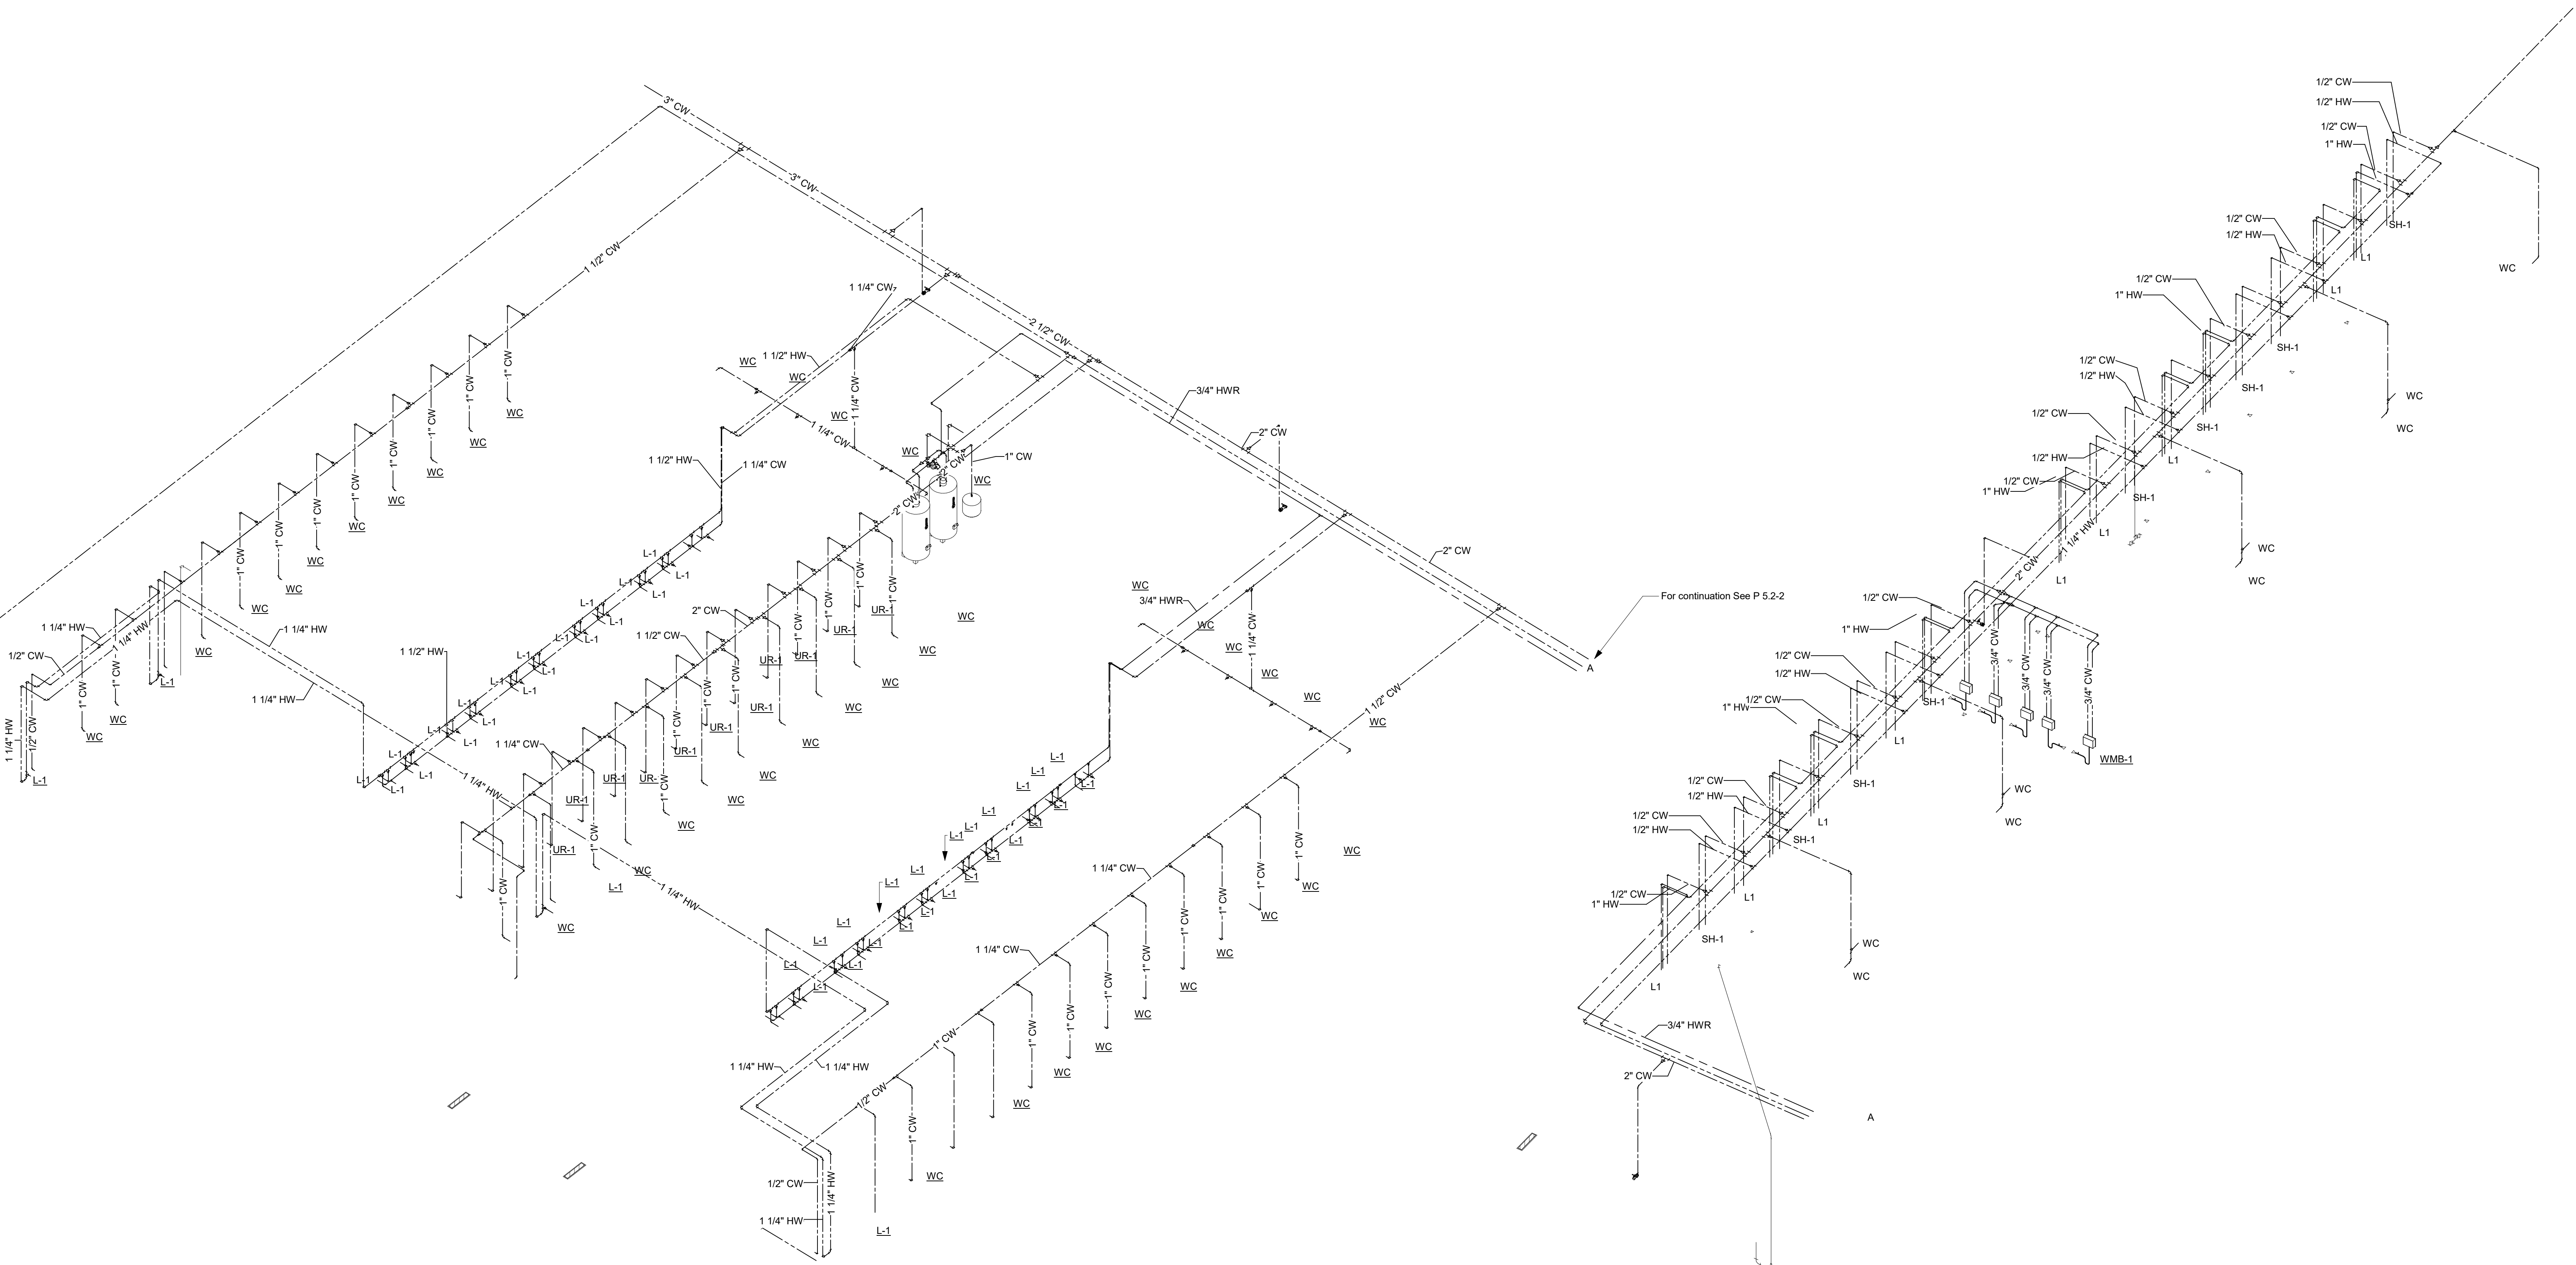

1 ENLARGED DW MENS/WOMENS GANG RESTROOM ISOMETRIC DIAGRAM
P5.2 SCALE:

2 ENLARGED DW SHOWERS ISOMETRIC DIAGRAM
P5.2 SCALE:

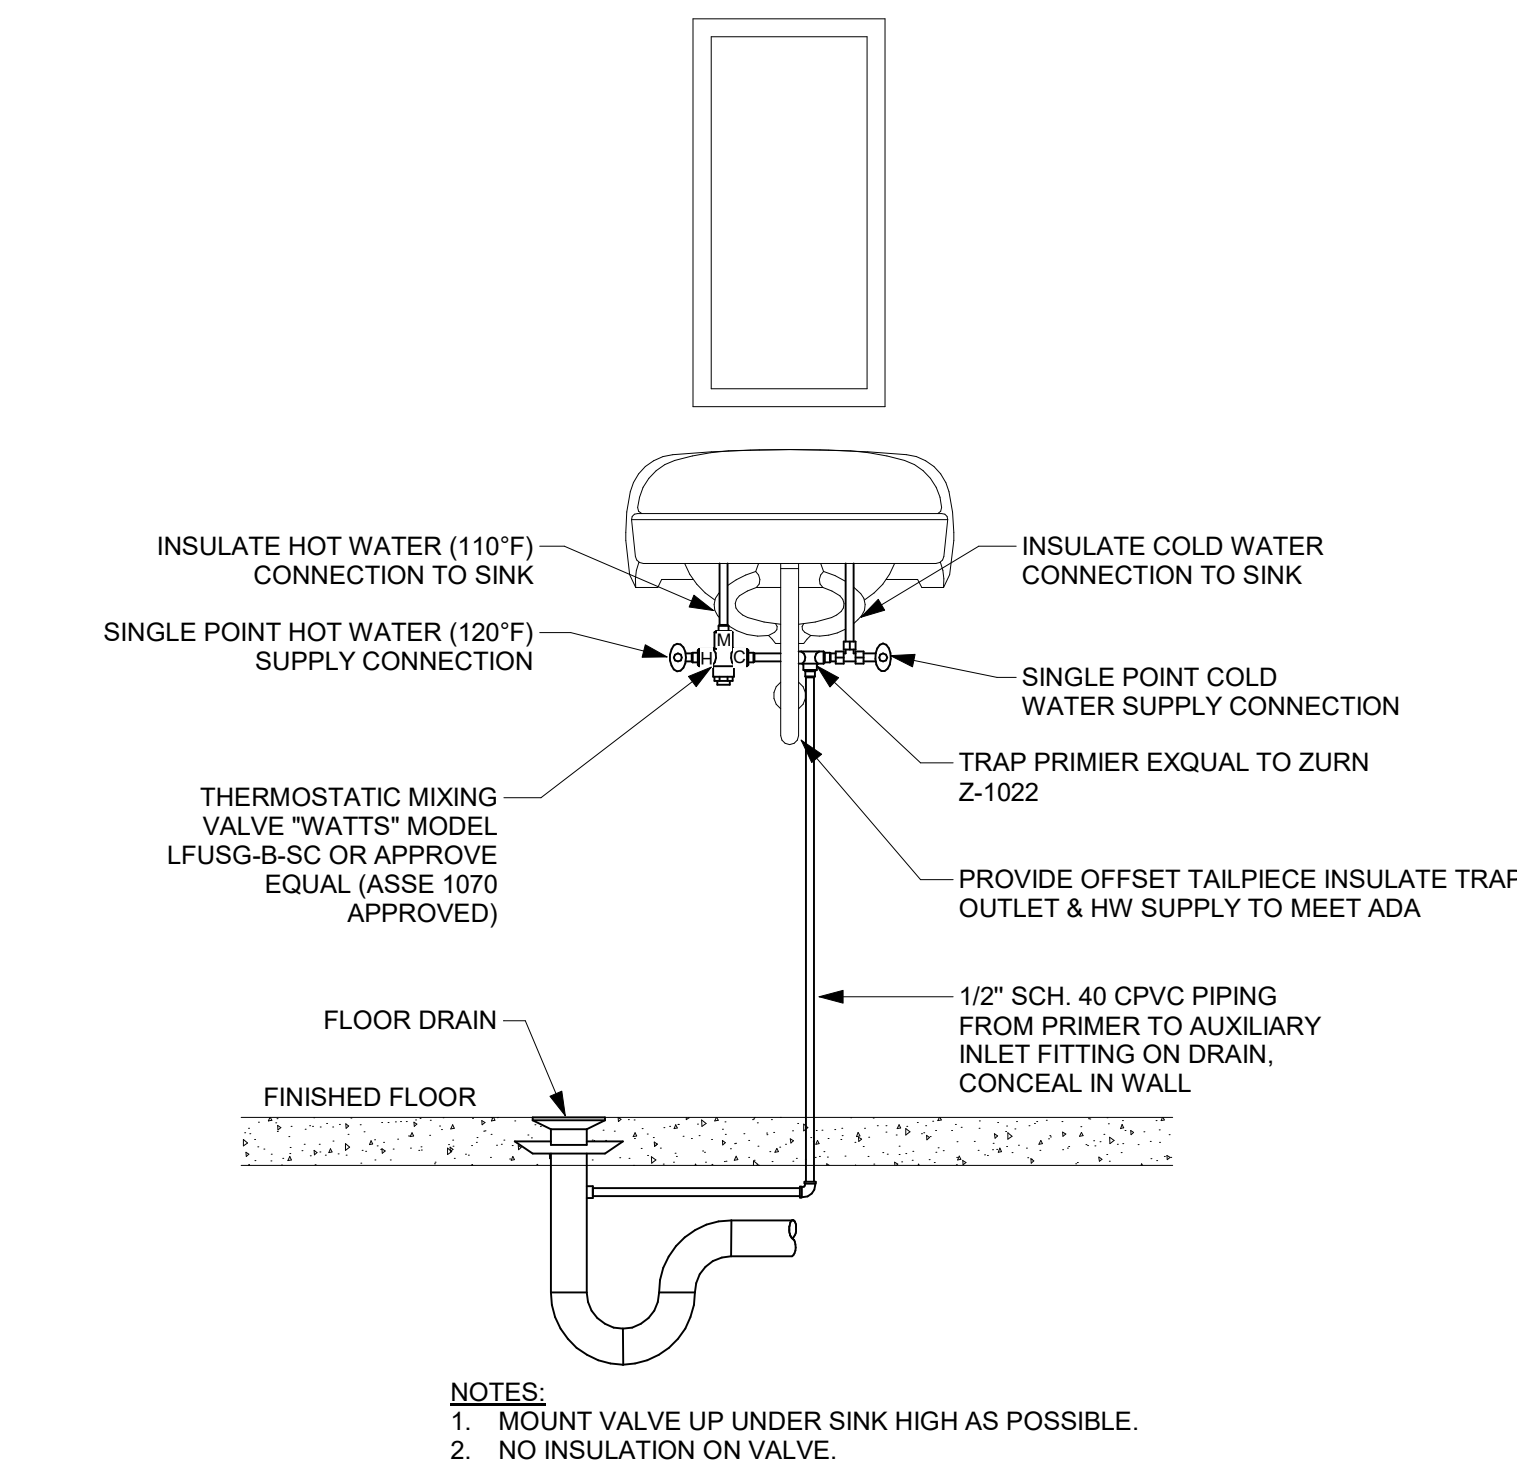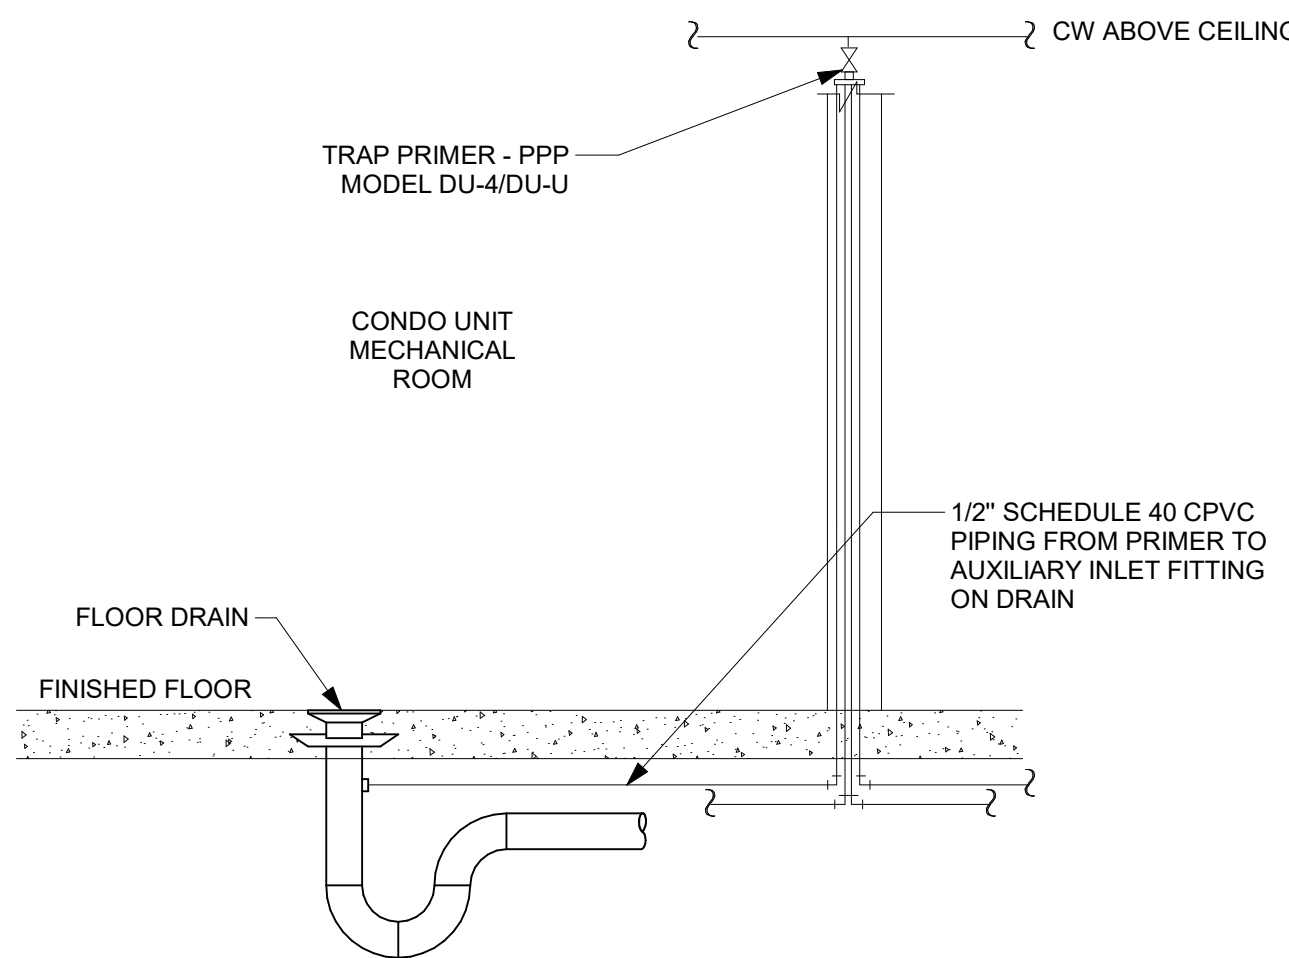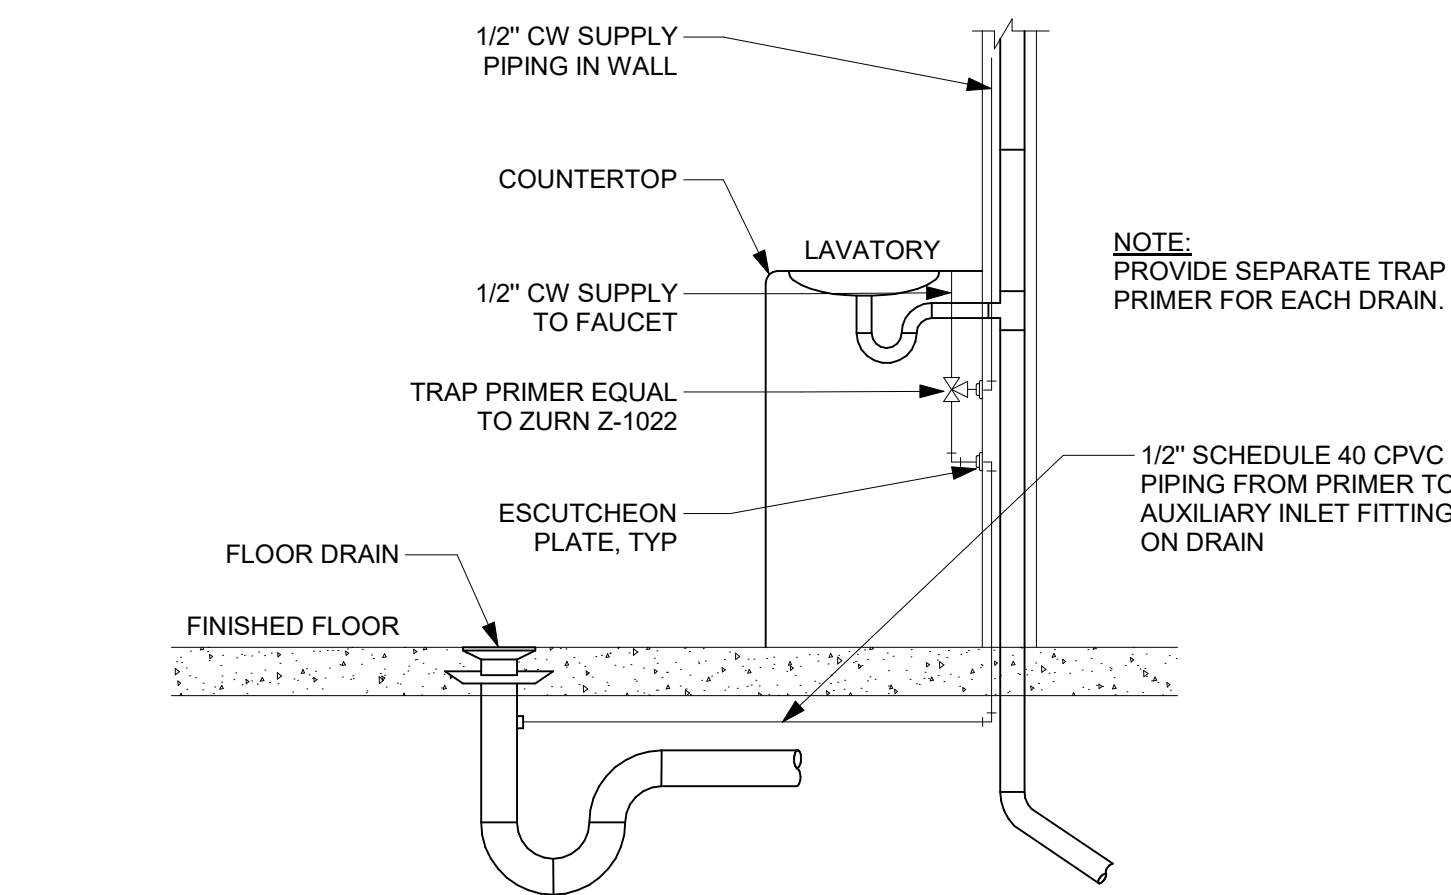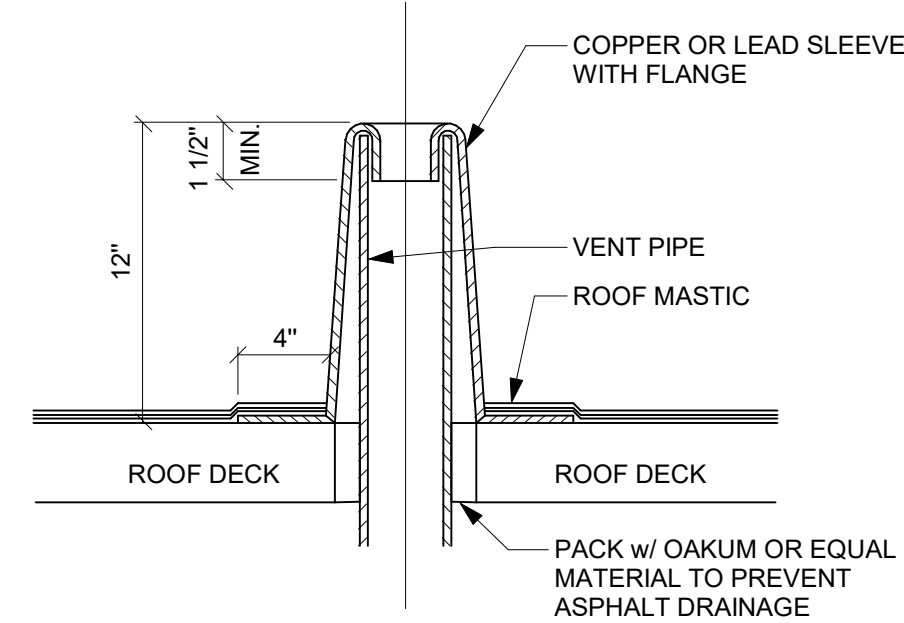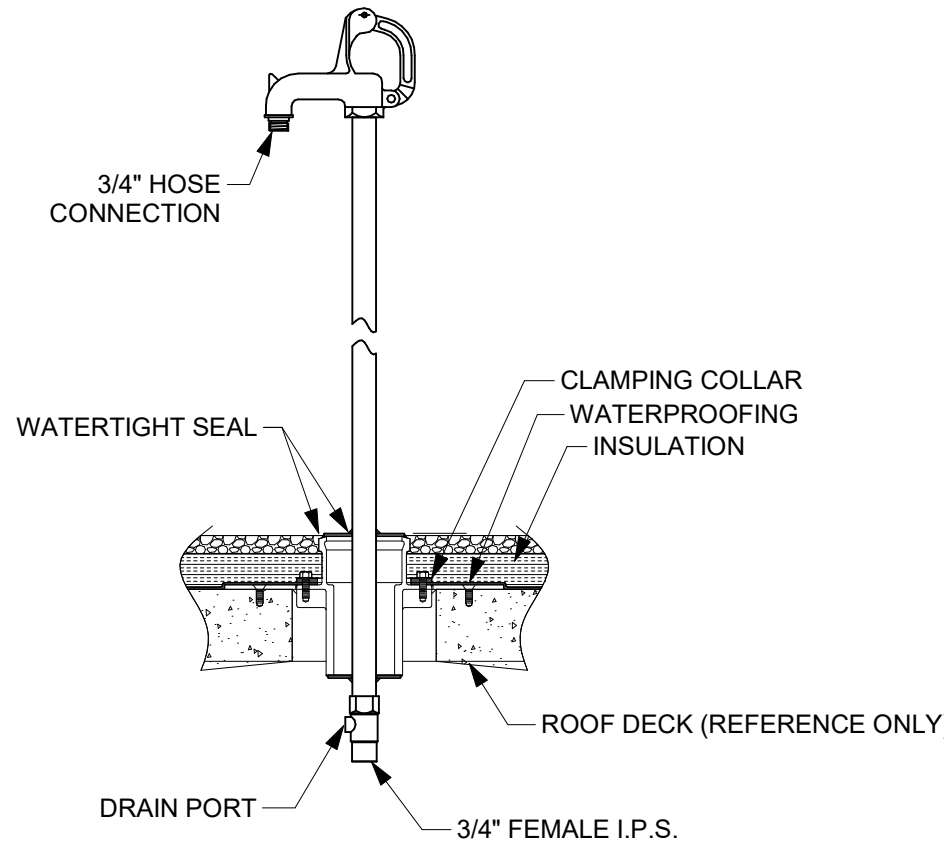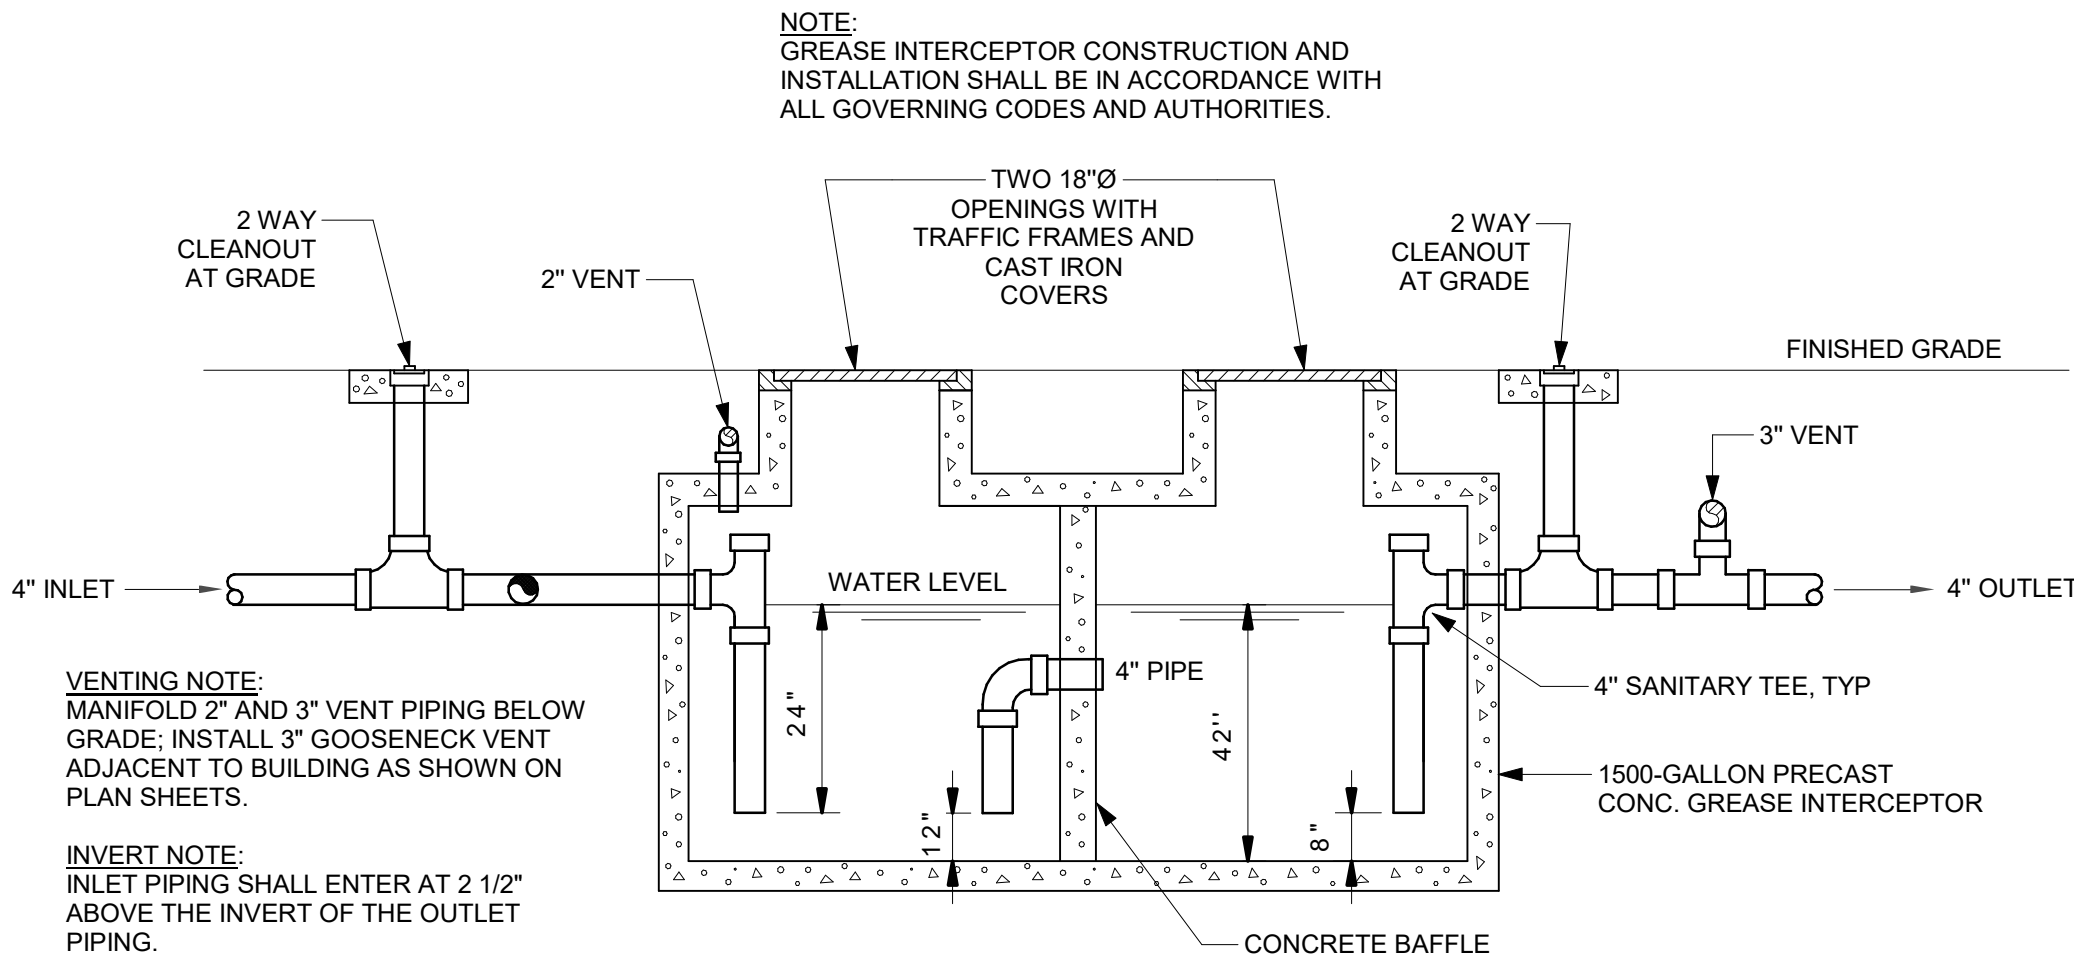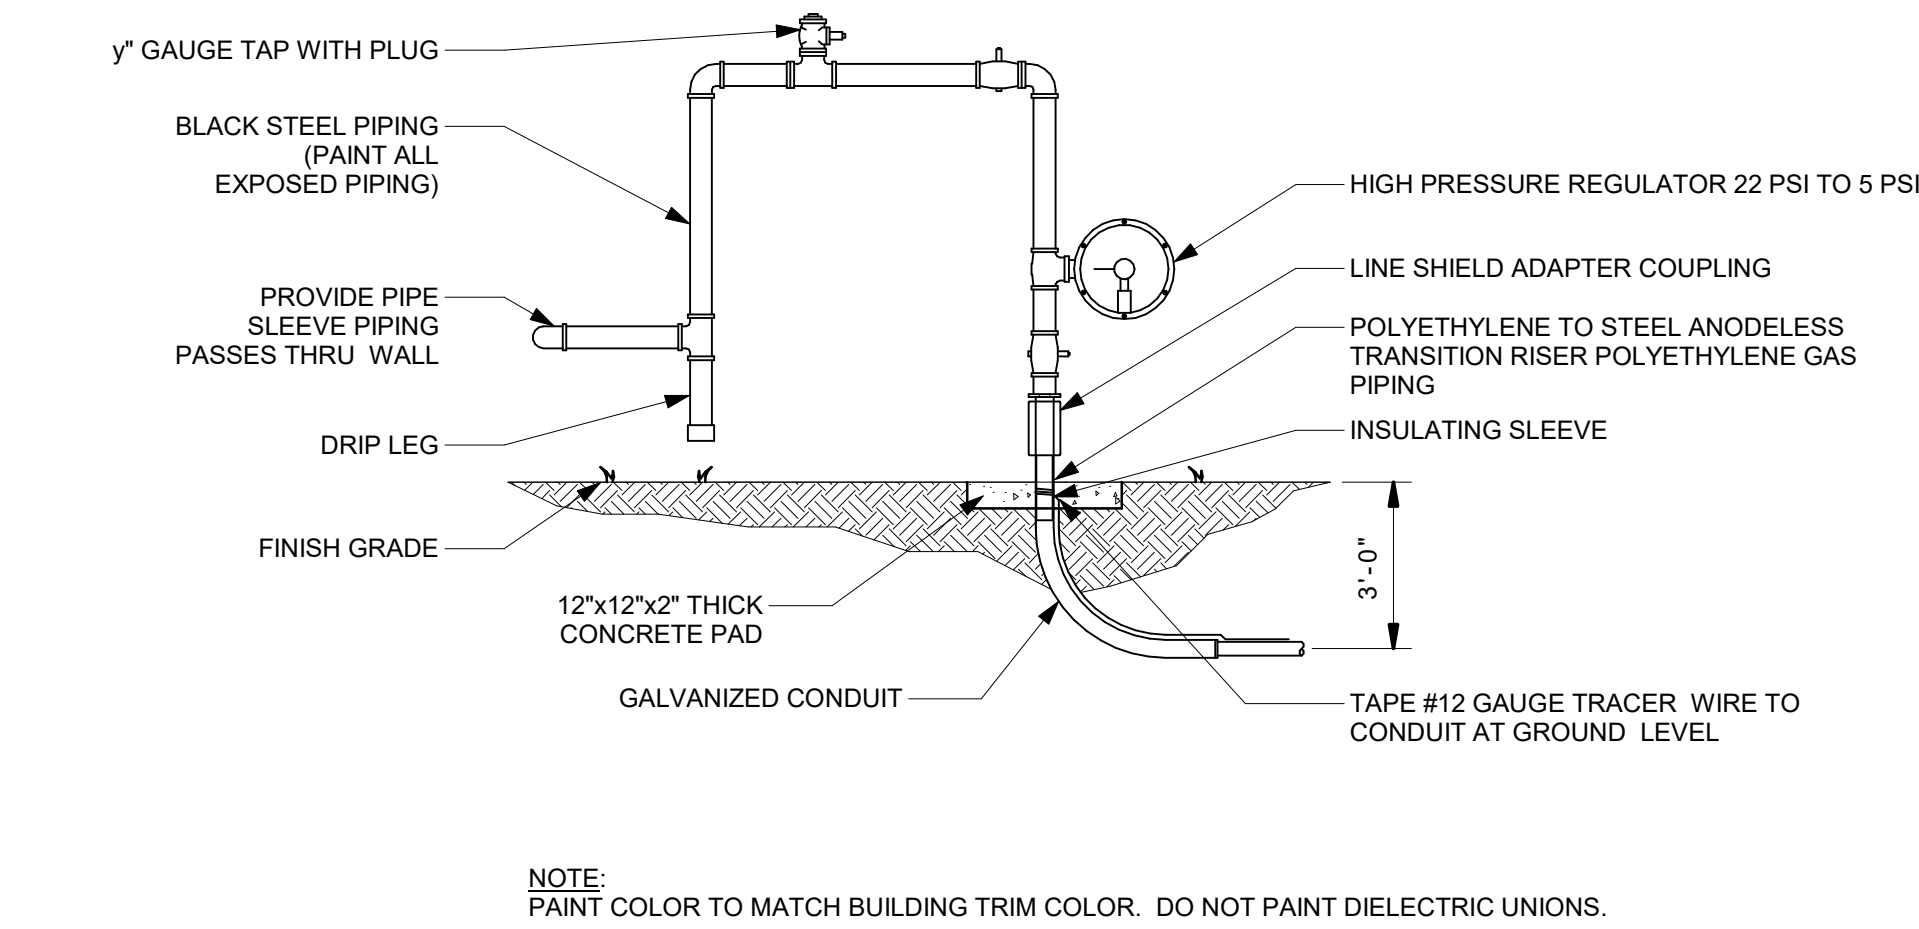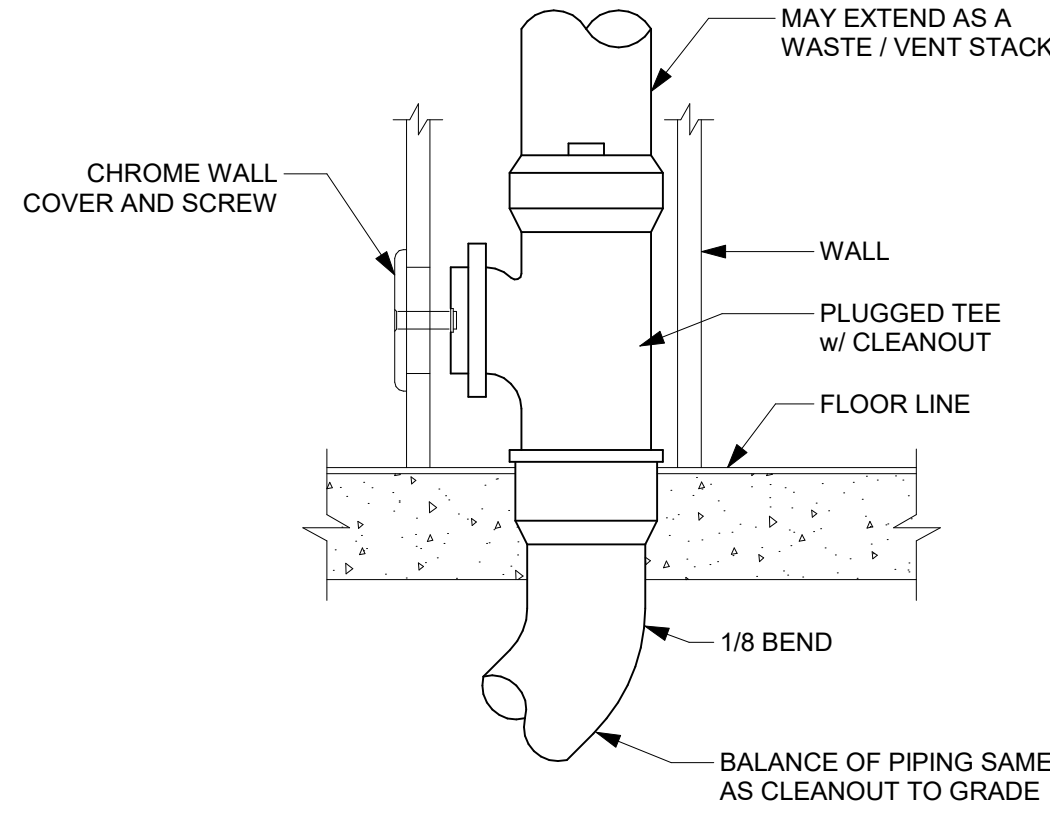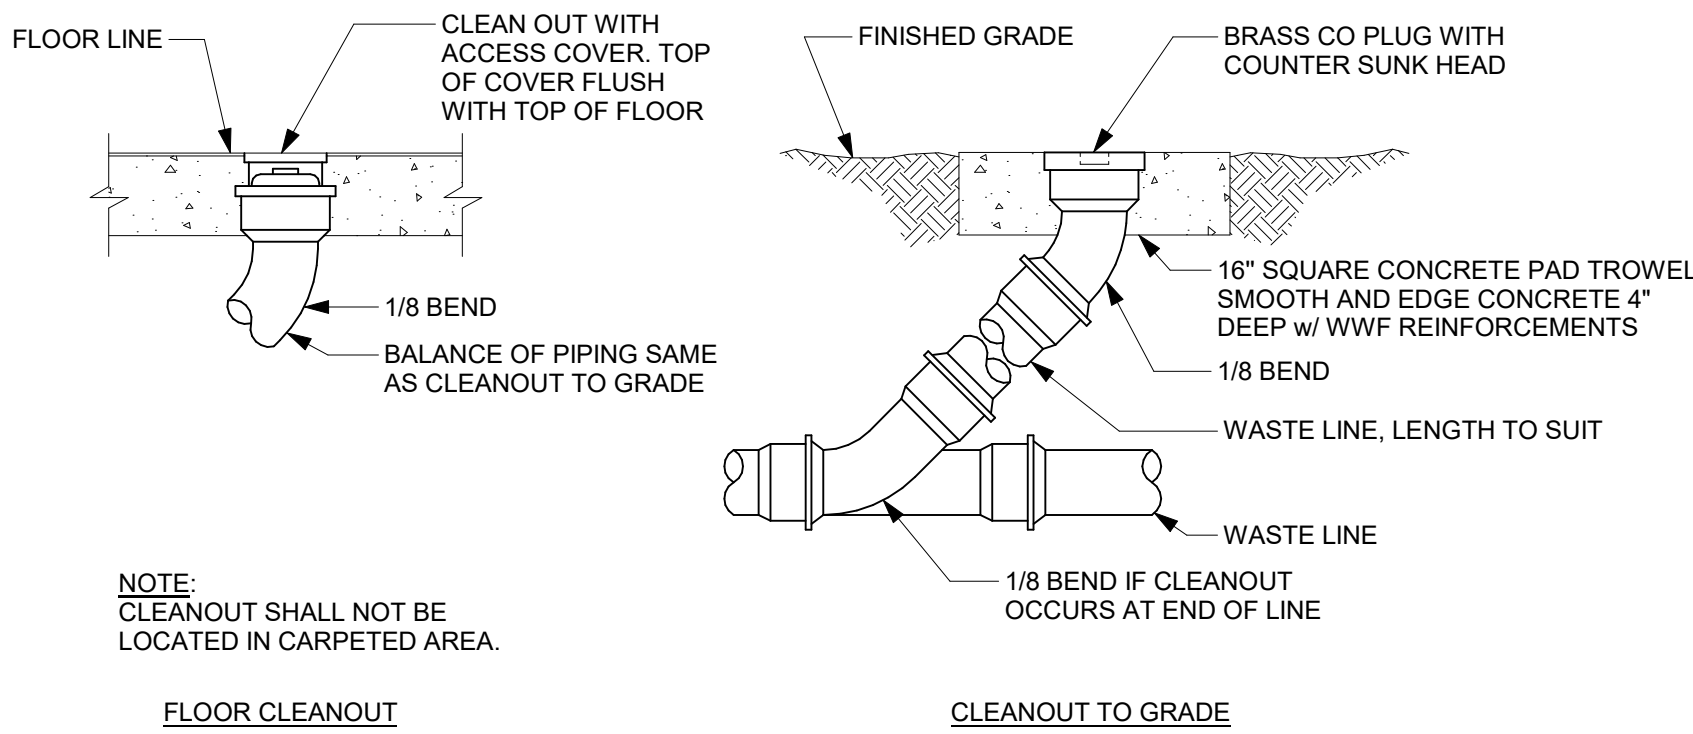

ALL REDLINE, SPECIFICATIONS, COMPUTER FILES, FIELD DATA AND OTHER DOCUMENTATION PREPARED BY KASPER ARCHITECTS & ASSOCIATES, INC. (K&A) IS IN FULL COMPLIANCE WITH THE PROFESSIONAL ENGINEERING AND ARCHITECTURE ACT, CHAPTER 481, F.S., AND THE PROFESSIONAL ENGINEERING AND ARCHITECTURE BOARD, CHAPTER 481.001, F.S. NO INFRINGEMENTS OF SERVICE SHALL REMAIN THE PROPERTY OF K&A. K&A SHALL RETAIN ALL COMMON LAW, STATUTORY AND OTHER RESERVED RIGHTS, INCLUDING THE COPYRIGHT HEREIN. THE DRAWINGS SHALL NEVER BE REPRODUCED IN WHOLE OR IN PART WITHOUT THE EXPRESS WRITTEN PERMISSION OF K&A.

PLUMBING SPECIFICATIONS

PART 1 - GENERAL

- 1.01 INSTRUCTIONS SCOPE OF WORK SHALL INCLUDE ALL MATERIALS, EQUIPMENT AND LABOR NECESSARY FOR A COMPLETE AND PROPERLY FUNCTIONING INSTALLATION OR BUSY BEE IN ELLISVILLE, FLORIDA IN ACCORDANCE WITH LOCAL AND STATE CODES, AND CONTRACT DRAWINGS AND SPECIFICATIONS.
- 1.02 LOCAL CONDITIONS CONTRACTOR SHALL VISIT THE SITE AND OBSERVE ALL EXISTING LOCAL CONDITIONS WHICH WOULD AFFECT WORK UNDER THIS CONTRACT. CONTRACTOR SHALL EXAMINE ALL PLANS AND SPECIFICATIONS FOR THIS PROJECT AND CONSULT THEM FOR INSTRUCTIONS PERTAINING TO WORK OF THIS SECTION.
- 1.03 PERMITS AND FEES CONTRACTOR SHALL OBTAIN ALL NECESSARY PERMITS AND INSPECTIONS REQUIRED FOR PERTAINING TO WORK UNDER THIS CONTRACT AND PAY ALL CHARGES INCIDENTAL THERETO. DELIVER TO ARCHITECT ALL CERTIFICATES OF INSPECTION ISSUED BY AUTHORITIES HAVING JURISDICTION.
- 1.04 CODES AND STANDARDS
- A. FURNISH AND INSTALL MECHANICAL SYSTEMS TO MEET ALL CURRENT REQUIREMENTS OF NATIONAL, STATE AND MUNICIPAL CODES, RULES, REGULATIONS, LAWS, AND STANDARDS AS THEY ARE ADOPTED BY THE GOVERNING AGENCY AND AS THEY MAY APPLY.
- 2023 FLORIDA BUILDING CODE – BUILDING, 8TH EDITION
 - 2023 FLORIDA BUILDING CODE – PLUMBING, 8TH EDITION
 - 2023 FLORIDA BUILDING CODE – MECHANICAL, 8TH EDITION
 - 2023 FLORIDA BUILDING CODE – FUEL GAS, 8TH EDITION
 - 2023 FLORIDA BUILDING CODE – ENERGY CONSERVATION, 8TH EDITION
 - 2023 FLORIDA BUILDING CODE – ACCESSIBILITY, 8TH EDITION
 - 2023 FLORIDA BUILDING CODE – TEST PROTOCOLS FOR HIGH-VELOCITY HURRICANE ZONES
 - NATIONAL ELECTRICAL CODE, NFPA 70.
- 1.05 SUBMITTALS
- A. MATERIAL LIST: WITHIN TWENTY (20) DAYS OF AWARD OF CONTRACT, CONTRACTOR SHALL SUBMIT TO ARCHITECT A COMPLETE LIST OF MATERIALS TO BE PROVIDED FOR THE WORK. THE LIST SHALL INCLUDE SUPPLIERS' NAMES AND MANUFACTURERS' NAMES AND NUMBER OR SERIES FOR EACH ITEM ON LIST.
- B. SHOP DRAWINGS: SUBMIT TO THE ARCHITECT FOR APPROVAL, BEFORE COMMENCING WORK. SHOP DRAWINGS FOR ALL MATERIALS AND EQUIPMENT TO BE PROVIDED UNDER THIS CONTRACT. THE FOLLOWING APPLIES TO THE SHOP DRAWINGS:
1. CONTRACTOR SHALL SUBMIT WITHIN 30-DAYS AFTER AWARD OF CONTRACT, DRAWINGS AND/OR CUT SHEETS OF ALL MATERIALS AND EQUIPMENT, AND 1/4" SCALE EQUIPMENT ROOM DRAWINGS FOR APPROVAL BY ARCHITECT/ENGINEER. SUCH SUBMITTALS MUST CONTAIN OUTLINE DIMENSIONS, OPERATING CLEARANCES, INSTALLATION, OPERATING AND MAINTENANCE INFORMATION AND SUFFICIENT ENGINEERING DATA TO INDICATE SUBSTANTIAL COMPLIANCE WITH SPECIFICATIONS. ALL SHOP DRAWINGS FOR ONE SECTION OF WORK OR ONE MECHANICAL SYSTEM SHALL BE SUBMITTED AT ONE TIME IN LOOSE-LEAF 3-RING BINDERS. NO APPROVAL WILL BE GIVEN IF SUBMITTED PIECEMEAL.
 2. WHERE CONTRACTOR CONSIDERS ADDITIONAL DETAIL OR SHOP DRAWINGS ESSENTIAL TO PROPER FABRICATION OR INSTALLATION OF EQUIPMENT, DUCTWORK, AND PIPING HE SHALL PREPARE SUCH CONSISTENT WITH CURRENT INDUSTRY METHODS AND STANDARDS. ENGINEER RESERVES THE RIGHT TO DIRECT REMOVAL AND REPLACEMENT OF ANY ITEMS WHICH, IN HIS OPINION, DO NOT PRESENT AN ORDERLY AND REASONABLY NEAT AND WORKMANLIKE APPEARANCE, PROVIDED SUCH AN ORDERLY INSTALLATION CAN BE MADE USING CUSTOMARY TRADE METHODS. REMOVAL AND REPLACEMENT SHALL BE DONE WHEN DIRECTED IN WRITING BY ENGINEER AT THE CONTRACTOR'S EXPENSE AND WITHOUT ADDITIONAL EXPENSE TO OWNER.
 3. APPROVAL, GRANTED ON SHOP DRAWINGS IS RENDERED AS A SERVICE ONLY AND SHALL NOT BE CONSIDERED AS GUARANTEE OF MEASUREMENTS OF BUILDING CONDITIONS, NOR SHALL IT BE CONSTRUED AS RELIEVING THE MECHANICAL CONTRACTOR OF BASIC RESPONSIBILITIES UNDER THIS CONTRACT.
 4. CHANGES IN FOUNDATIONS, BASES, CONNECTIONS, PIPING, CONTROLS, STARTERS, ELECTRICAL EQUIPMENT, WIRING AND CONDUIT, SPACE OPENINGS, WALLS AND CEILINGS, AND VIBRATION ISOLATION IN ORDER TO ACCOMMODATE SUBSTITUTE EQUIPMENT SHALL BE MADE AT NO ADDITIONAL COST TO THE OWNER.
 5. CONTRACTOR SHALL SUBMIT SHOP DRAWINGS AND RECEIVE ENGINEER'S APPROVAL BEFORE INSTALLING MATERIALS OR EQUIPMENT. ANY EQUIPMENT OR MATERIALS INSTALLED PRIOR TO RECEIPT OF APPROVAL SHALL BE REMOVED FROM THE PROJECT. CONTRACTOR SHALL BE SUBJECT TO REMOVAL AND/OR ALTERATION AT THE DISCRETION OF THE MECHANICAL ENGINEER AT NO ADDITIONAL COST.
 6. APPROVAL OF ANY SUBMITTED DATA OR SHOP DRAWINGS FOR MATERIALS, EQUIPMENT, APPARATUS DEVICES, ARRANGEMENTS AND/OR LAYOUTS WILL NOT RELIEVE THE CONTRACTOR FROM RESPONSIBILITY OF FURNISHING SAME OF PROPER DIMENSIONS, CAPACITIES, SIZES, QUANTITIES AND INSTALLATION DETAILS TO EFFICIENTLY PERFORM REQUIREMENTS AND INTENT OF CONTRACT. SUCH APPROVAL SHALL NOT RELIEVE CONTRACTOR FROM RESPONSIBILITY FOR ERRORS OF ANY SORT.
- C. ANY ELECTRICAL DEVIATIONS BETWEEN THE CONTRACT DOCUMENTS AND THE FURNISHED EQUIPMENT MUST BE SEPARATELY ACKNOWLEDGED BY A SUBSTITUTION REQUEST AND ADDITIONALLY NOTED ON THE SUBMITTAL.
- D. PROVIDE PLUMBING SHOP DRAWINGS FOR: WASTE AND VENT PIPING, DOMESTIC WATER PIPING, VALVES, PLUMBING FIXTURES AND PIPE INSULATION.
- 1.06 CONNECTING TO WORK OF OTHERS
- A. BEFORE STARTING HIS WORK, AND FROM TIME TO TIME AS WORK PROGRESSES, PLUMBING CONTRACTOR SHALL EXAMINE WORK AND MATERIALS INSTALLED BY OTHERS INsofar AS THEY APPLY TO HIS WORK AND SHALL NOTIFY ENGINEER IMMEDIATELY IN WRITING IF CONDITIONS EXIST WHICH WILL SHOULD CONTRACTOR START HIS WORK WITHOUT SUCH NOTIFICATION. IT SHALL BE CONSTRUED AS:
- B. AN ACCEPTANCE BY HIM OF ALL CLAIMS OR QUESTIONS AS TO SUITABILITY OR WORK OF OTHERS TO RECEIVE HIS WORK. HE SHALL REMOVE AND REPLACE AT HIS OWN EXPENSE, ALL WORK UNDER THIS CONTRACT WHICH MAY HAVE TO BE REMOVED ON ACCOUNT OF SUCH DEFECTS.
- 1.07 CONTRACT DRAWINGS
- A. IT IS THE INTENT OF DRAWINGS AND SPECIFICATIONS TO OBTAIN A COMPLETE AND FULLY OPERATIONAL, AND SATISFACTORY INSTALLATION. AN ATTEMPT HAS BEEN MADE TO SEPARATE AND COMPLETELY DEFINE WORK UNDER THIS CONTRACT. HOWEVER, SUCH SEPARATE DIVISIONAL DRAWINGS AND SPECIFICATIONS SHALL NOT RELIEVE CONTRACTOR FROM FULL RESPONSIBILITY OF COMPLIANCE WITH WORK OF HIS TRADE WHICH MAY BE INDICATED ON ANY DRAWING OR IN ANY SECTION OF THE SPECIFICATIONS.
- B. CONTRACTOR SHALL CAREFULLY EXAMINE ARCHITECTURAL, STRUCTURAL, ELECTRICAL, AND MECHANICAL DRAWINGS PRIOR TO SUBMITTING BID. CONTRACTOR WILL BE REQUIRED TO FURNISH, INSTALL AND CONNECT WITH APPROPRIATE SERVICES ALL ITEMS SHOWN ON ANY DRAWINGS WITHOUT ADDITIONAL EXPENSE TO OWNER. ARCHITECT SHALL BE NOTIFIED PRIOR TO BID DATE OF ANY DISCREPANCIES, OMISSIONS, CONFLICTS OR INTERFERENCE WHICH OCCUR BETWEEN DRAWINGS OR BETWEEN DRAWINGS AND SPECIFICATIONS. IF SUCH NOTIFICATION IS RECEIVED IN ADEQUATE TIME, ADDITIONAL DATA OR CHANGES WILL BE ISSUED BY ADDENDUM TO ALL BIDDERS. SUBMITTAL OF BID BY CONTRACTOR SHALL INDICATES THE CONTRACTOR'S ACKNOWLEDGEMENT AND ACCEPTANCE TO PROVIDE ALL NECESSARY EQUIPMENT, MATERIALS AND LABOR TO MEET THE INTENT OF THE DRAWINGS AND SPECIFICATIONS IN ACCORDANCE WITH ALL CODE REQUIREMENTS.
- C. ARCHITECTURAL DRAWINGS SHALL TAKE PRECEDENCE OVER MECHANICAL DRAWINGS WITH REFERENCE TO BUILDING CONSTRUCTION. PLUMBING DRAWINGS ARE DIAGRAMMATIC BUT SHALL BE FOLLOWED AS CLOSELY AS ACTUAL CONSTRUCTION OF BUILDING AND WORK OF OTHER TRADES WILL PERMIT. WHERE LOCATIONS OF EQUIPMENT, DEVICES OR FIXTURES ARE CONTROLLED BY ARCHITECTURAL FEATURES, ESTABLISH SUCH LOCATIONS BY REFERRING TO DIMENSIONS ON ARCHITECTURAL DRAWINGS AND NOT BY SCALING DRAWINGS. CHANGES FROM DRAWINGS NECESSARY TO MAKE WORK OF CONTRACTOR CONFORM WITH BUILDING AS CONSTRUCTED AND TO FIT WORK OF OTHER TRADES OR RULES OF BOODIES HAVING JURISDICTION SHALL BE MADE BY CONTRACTOR AT HIS OWN EXPENSE. SOME DRAWINGS MAY HAVE BEEN PREPARED FROM EXISTING DRAWINGS WITH INTENT OF PROVIDING THE CONTRACTOR WITH INFORMATION CONCERNING THE EXISTING CONDITIONS. DATA SHOWN HAS NOT BEEN COMPLETELY VERIFIED BY ARCHITECT/ENGINEER AND NO GUARANTEE OF ACCURACY OF THIS INFORMATION IS GIVEN OR INTENDED. IT SHALL BE THE RESPONSIBILITY OF CONTRACTOR TO VERIFY ALL EXISTING CONDITIONS. DATA WHICH IS SHOWN BUT PROVES TO BE INCORRECT SHALL IN NO WAY RELIEVE THE CONTRACTOR FROM INSTALLING HIS WORK WITHIN THE INTENT OF PLANS AND SPECIFICATIONS, NOR SHALL IT CONSTITUTE BASIS FOR A CHANGE ORDER UNLESS, IN THE OPINION OF THE ARCHITECT/ENGINEER IT IS DETERMINED TO BE AN EXTRA COST OVER AND ABOVE THE BASIC INTENT OF THESE PLANS AND SPECIFICATIONS.
- 1.08 DAMAGE TO OTHER WORK
- A. CONTRACTOR SHALL BE RESPONSIBLE FOR PROPER PROTECTIVE MEASURES WHEN WORKING OVERHEAD OR IN FINISHED AREAS. HE/SHE SHALL REPAIR, REPLACE OR TOUCH-UP ALL FINISHED SURFACES WHICH MAY BE DAMAGED AS A RESULT OF HIS OPERATIONS.
- 1.09 STORAGE AND WORK AREAS
- A. ALL EQUIPMENT AND MATERIALS SHALL BE PROTECTED FROM THE WEATHER, DAMAGE, MOISTURE, DIRT, DEBRIS, ETC. USE OF CARDBOARD, VISQUEEN, OR OTHER SIMILAR MATERIALS WHILE STORED OUTSIDE IS NOT ACCEPTABLE. DO NOT INSTALL DAMAGED EQUIPMENT.
- 1.10 APPROVAL OF MATERIAL
- A. EQUIPMENT OTHER THAN SPECIFIED IN THE CONTRACT DOCUMENTS REQUIRES APPROVAL FROM ENGINEER 10 DAYS PRIOR TO BID DATE.
- B. WRITTEN REQUEST FOR PRIOR APPROVAL MUST BE RECEIVED IN ENGINEER'S OFFICE BY CLOSE OF BUSINESS NO LATER THAN 10 DAYS PRIOR TO SCHEDULED BID DATE. REQUEST SHALL CONTAIN DETAILED INFORMATION ON THE PROPOSED ITEM. THIS SHALL INCLUDE:
1. CATALOG CUTS SHEETS
 2. DETAILED SPECIFICATIONS
 3. DESCRIPTION OF DEVIATION FROM SPECIFIED ITEM.
- C. AN ADDENDA SHALL BE ISSUED LISTING ALL PROSPECTIVE CONTRACTORS LISTING ALL PRIOR APPROVED MANUFACTURERS AND PRODUCTS.

PART 2 - PRODUCTS

- 2.01 PLUMBING SYSTEMS
- A. PIPE MATERIALS:
1. DWV (DRAIN, WASTE, AND VENT) PIPING: FITTINGS SHALL BE LONG RADIUS FITTINGS, EXCEPT FITTINGS IN VENT PIPING MAY BE SHORT RADIUS FITTINGS. MINIMUM SIZE PIPING SHALL BE 2 INCHES FOR BURIED PIPING AND 1 1/4 INCHES FOR ABOVEGROUND PIPING. CONTRACTOR'S OPTION:
 - A. BELOW GRADE: CAST IRON, ASTM A74, STANDARD, SINGLE HUB, COATED, WITH JOINTS CAULKED AND LEADED.
 - B. ABOVE GRADE: CAST IRON, NO HUB, CISPI STANDARD 301, WITH CAST IRON COUPLING WITH GASKET AND STAINLESS STEEL BANDS
 - C. ABOVE AND BELOW GRADE: PVC, SCHEDULE 40, MEETING ASTM D1785, WITH SOLVENT WELD JOINTS MEETING ASTM D2564.
 2. DOMESTIC WATER PIPING (CONTRACTOR'S OPTION):
 - A. BELOW GRADE:
 - 1. COPPER, MEETING ASTM B88, TYPE K, COATED WITH COAL TAR SHELLAC, 95/5 SOLDERED JOINTS.
 - 2. SDR PIPE: PVC, SCHEDULE 40, MEETING ASTM 2241.
 - B. ABOVE GRADE:
 - 1. CPVC, MEETING ASTM D2846 AND F441. PIPING UP TO 1 1/4" SHALL BE SCHEDULE 40. PIPING 1 1/2" AND LARGER SHALL BE SCHEDULE 80. SOLVENT WELD JOINTS.
 - 2. COPPER, MEETING ASTM B88, TYPE L, WITH 95/5 SOLDERED JOINTS.
 - C. DIELECTRIC UNIONS: SHALL BE USED AT ALL JOINTS OF DISSIMILAR PIPE MATERIALS.
 3. ROOF DRAINAGE PIPING: SAME AS DWV ABOVE. INSULATE ALL ROOF DRAINAGE PIPE ABOVE GROUND.
- B. PIPING INSULATION:
1. ELECTRIC WATER COOLER WASTE:
 - A. 3/4-LB., 1 1/2 INCH BLANKET.
 - B. FSK JACKET.
 2. DOMESTIC COLD AND HOT WATER MAINS AND RISERS:
 - A. 1-INCH STANDARD FIBERGLASS.
 - B. FACTORY JACKET AND FITTING COVERS.
 3. DOMESTIC WATER PIPING EXPOSED TO EXTERIOR:
 - A. NITRILE RUBBER BASED ELASTOMERIC SHEET INSULATION; ARMSTRONG "ARMAFLEX 2", MINIMUM INSULATION THICKNESS SHALL BE 3/4-INCH.
 - B. CPVC WATER PIPING AND PVC WASTE, VENT AND ROOF DRAIN PIPING RUN IN RETURN AIR FLENUMS.
 - C. WRAP WITH A FIRE PROTECTIVE JACKET WITH A MAXIMUM FLAME SPREAD RATING OR 25 AND A MAXIMUM SMOKE DEVELOPMENT RATING OF 50 IN ACCORDANCE WITH NFPA-90A, PARAGRAPHS 2.3.1 AND 2.3.10.1.
 5. PIPING TO BE UNINSULATED: PIPING RUN-OUTS TO FIXTURES (EXCEPT AS NOTED FOR HANDICAP-ACCESSIBLE FIXTURES).
- C. ACCEPTABLE MANUFACTURERS:
1. MANUFACTURERS' MODEL NUMBERS ARE LISTED TO ESTABLISHED A STANDARD OF QUALITY AND LEVEL OF PERFORMANCE.
 2. EQUIVALENT ITEMS OF THE FOLLOWING MANUFACTURES ARE ACCEPTABLE:
 - A. FIXTURES: SEE FIXTURE SCHEDULE.
 - 1. AMERICAN-STANDARD, ELJER, KOHLER, CRANE, ELKAY, JUST, AND BRIGGS.
 - B. FIXTURE TRIM: SEE FIXTURE SCHEDULE.
 - 1. AMERICAN-STANDARD, KOHLER, SPEAKMAN, MOEN, DELTA, T&S BRASS, CHICAGO FAUCET, SYMMONS, BRIGGS.
 - C. DRAIN AND FIXTURE SPECIALTIES: J. R. SMITH, JOSAM, ZURN.
 - A. FLOOR AND EXTERIOR CLEANOUTS: ZURN-1440 OR EQUAL.
 - B. WALL CLEANOUT: ZURN-1441 OR EQUAL W/ SMOOTH SECURED COVER.
 - C. FLOOR DRAINS: SEE SCHEDULE 1.
 - D. ROOF DRAINS: ZURN-100 OR EQUAL.
 - E. WATER COOLERS: SEE FIXTURE SCHEDULE, OASIS, ELKAY, HALSEY TAYLOR.
 - F. WATER HEATERS: SEE FIXTURE SCHEDULE, RHEEM, A.O. SMITH, STATE, LOCHINVAR.
 - G. WATER SYSTEM SPECIALTIES.
 - H. WATER HAMMER ARRESTORS SHALL CONFORM TO PDI WH201 AND ASSIE 1010.
 - I. ACCEPTABLE: ZURN SHOCKTROLS 2-1700 OR EQUAL.
 - B. WALL HYDRANTS AND HOSE BIBBS: SEE FIXTURE SCHEDULE.
- 2.03 PIPING SPECIALTIES
- A. ESCUTCHEONS SHALL BE MANUFACTURED WALL, CEILING AND FLOOR PLATES: DEEP-PATTERN TYPE WHEN REQUIRED TO CONCEAL PROTRUDING FITTINGS AND SLEEVES. CONSTRUCT OF ONE-PIECE CAST BRASS WITH POLISHED CHROME PLATE FINISH AND SET-SCREW.
- 2.04 PIPE INSULATION
- A. FLEXIBLE ELASTOMERIC CELLULAR INSULATION, TYPE I, ASTM C 534, FLEXIBLE EXPANDED CLOSED-CELL STRUCTURE WITH SMOOTH SKIN ON BOTH SIDES, PRODUCT AS MANUFACTURED BY ARMSTRONG OR EQUIVALENT BY RUBATX OR HALSTEAD, AVERAGE MAXIMUM THERMAL CONDUCTIVITY SHALL BE 0.30 AT 75 DEG F.
- B. FLEXIBLE ELASTOMERIC CELLULAR INSULATION ADHESIVE, SOLVENT-BASED, CONTACT ADHESIVE RECOMMENDED BY INSULATION MANUFACTURER.
- 2.05 HANGERS AND SUPPORTS
- A. PROVIDE HANGERS, RODS, AND SUPPORT CLAMPS AS REQUIRED TO PROPERLY SUPPORT PIPING FROM STRUCTURE.
- B. PROVIDE BUILDING ATTACHMENTS OR CONCRETE INSERTS APPROPRIATE FOR BUILDING MATERIALS.
- 2.06 SLEEVES
- A. WALLS AND PARTITIONS:
1. PIPE SLEEVES 8-INCH DIAMETER AND SMALLER (ABOVE GRADE): SLEEVES SHALL BE MILD STEEL, PIPE OR PLASTIC SLEEVES BUILT INTO WALL, PARTITION OR BEAM, SIZED TO PASS PIPE AND COVERING, LEAVING A CLEAR SPACE OF 1/4-INCH MINIMUM BETWEEN COVERING AND SLEEVE. PENETRATIONS OF FIRE RATED BARRIERS SHALL HAVE MILD STEEL SLEEVES.
 2. PIPE SLEEVES INSTALLED IN EXTERIOR WALLS BELOW GRADE: SCHEDULE 40 STEEL, HOT DIPPED GALVANIZED AFTER FABRICATION OR CAST IRON SLEEVE WITH 1/4-INCH X 3-INCH CENTER FLANGE (WATER STOP) AROUND THE OUTSIDE.
- B. PIPE SLEEVES IN FLOORS (ABOVE GRADE): SLEEVES SHALL BE 14 GAUGE GALVANIZED SHEET STEEL OR PLASTIC, SET BEFORE FLOOR IS POURED, SIZED TO PASS PIPE AND COVERING, LEAVING A CLEAR SPACE OF 1/4-INCH BETWEEN COVERING AND SLEEVE, AND SHALL EXTEND 12-INCH ABOVE FINISHED FLOOR.
- C. SEALING OF SLEEVES:
1. SLEEVES BELOW GRADE: CAULK ANNUAL SPACE BETWEEN PIPE AND SLEEVE USING OKUMUM AND POURED LEAD BOTH SIDES MINIMUM ONE INCH DEEP TO MAKE WALL PENETRATION WATER TIGHT.
 2. SLEEVES ABOVE GRADE: OPENINGS AROUND PIPES, DUCT, ETC., PASSING THROUGH SLEEVES SHALL BE MADE DRAFT FREE AND VERMIN-PROOF BY PACKING SOLIDLY WITH MINERAL WOOL OR FIBERGLASS.
 3. SEALING OF SLEEVES THROUGH FIRE RATED BARRIERS: OPENINGS AROUND PIPES, ETC., THROUGH FIRE RATED BARRIERS SHALL BE SEALED USING AN UL APPROVED METHOD RATED AT LEAST EQUAL TO THE WALL BEING PENETRATED.

PART 3 - EXECUTION

- 3.01 PIPE INSULATION INSTALLATION
- A. INSTALL ONE INCH THICK PIPE INSULATION ON HOT WATER PIPING. INSTALL ONE INCH THICK PIPE INSULATION ON COLD WATER PIPING THAT IS ABOVE THE ROOF INSULATION.
- B. INSTALL INSULATION IN STRICT ACCORDANCE WITH MANUFACTURERS WRITTEN RECOMMENDATIONS.
- 3.02 TESTING OF WATER DISTRIBUTION SYSTEMS
- A. TEST FOR LEAKS AND DEFECTS IN NEW WATER DISTRIBUTION PIPING SYSTEMS. IF TESTING IS PERFORMED IN SEGMENTS, SUBMIT A SEPARATE REPORT FOR EACH TEST, COMPLETE WITH DIAGRAM OF PORTION OF SYSTEM TESTED.
- B. LEAVE UNCOVERED AND UNCONCEALED NEW WATER DISTRIBUTION PIPING UNTIL IT HAS BEEN TESTED AND APPROVED. EXPOSE WORK THAT HAS BEEN COVERED OR CONCEALED BEFORE IT HAS BEEN TESTED AND APPROVED FOR TESTING.
- C. CAP AND SUBJECT THE PIPING SYSTEM TO A STATIC WATER PRESSURE OF 50 PSIG ABOVE THE OPERATING PRESSURE WITHOUT EXCEEDING PRESSURE RATING OF PIPING SYSTEM MATERIALS. ISOLATE TEST SOURCE AND ALLOW TO STAND FOR 4 HOURS. LEAKS AND LOSS IN TEST PRESSURE CONSTITUTE DEFECTS THAT MUST BE REPAIRED.
- D. REPAIR LEAKS AND DEFECTS WITH NEW MATERIALS AND RETEST SYSTEM OR PORTION THEREOF UNTIL SATISFACTORY RESULTS ARE OBTAINED.
- E. PREPARE REPORTS FOR TESTS AND REQUIRED CORRECTIVE ACTION.
- 3.03 TESTING OF DRAINAGE AND VENT PIPING SYSTEMS
- A. TEST FOR LEAKS AND DEFECTS IN NEW DRAINAGE AND VENT PIPING SYSTEMS. IF TESTING IS PERFORMED IN SEGMENTS, SUBMIT A SEPARATE REPORT FOR EACH TEST, COMPLETE WITH A DIAGRAM OF THE PORTION OF THE SYSTEM TESTED.
- B. LEAVE UNCOVERED AND UNCONCEALED NEW DRAINAGE AND VENT PIPING UNTIL IT HAS BEEN TESTED AND APPROVED. EXPOSE FOR TESTING WORK THAT HAS BEEN COVERED OR CONCEALED BEFORE IT HAS BEEN TESTED AND APPROVED.
- C. TEST PIPING OF PLUMBING DRAINAGE AND VENTING SYSTEMS ON COMPLETION OF ROUGH-IN PIPING INSTALLATION. TIGHTLY CLOSE ALL OPENINGS IN PIPING SYSTEM AND FILL WITH WATER TO POINT OF OVERFLOW, BUT NOT LESS THAN 5 FEET HEAD OF WATER. WATER LEVEL SHALL NOT DROP DURING THE PERIOD FROM 15 MINUTES BEFORE INSPECTION STARTS THROUGH COMPLETION OF INSPECTION. INSPECT JOINTS FOR LEAKS. AFTER PLUMBING FIXTURES HAVE BEEN SET AND THEIR TRAPS FILLED WITH WATER, TEST CONNECTIONS AND PROVE GASTIGHT AND WATERTIGHT. PLUG STACK OPENINGS ON ROOF AND BUILDING DRAIN WHERE IT LEAVES THE BUILDING AND INTRODUCE AIR INTO THE SYSTEM EQUAL TO PRESSURE OF 1-INCH WATER COLUMN. USE A U TUBE OR MANOMETER INSERTED IN THE TRAP OF A WATER CLOSET TO MEASURE THIS PRESSURE. AIR PRESSURE SHALL REMAIN CONSTANT WITHOUT INTRODUCING ADDITIONAL AIR THROUGHOUT PERIOD OF INSPECTION. INSPECT PLUMBING FIXTURE CONNECTIONS FOR GAS AND WATER LEAKS.
- D. REPAIR LEAKS AND DEFECTS USING NEW MATERIALS AND RETEST SYSTEM OR PORTION THEREOF UNTIL SATISFACTORY RESULTS ARE OBTAINED.
- E. PREPARE REPORTS FOR TESTS AND REQUIRED CORRECTIVE ACTION.
- 3.04 CLEANING
- A. PURGE NEW POTABLE WATER DISTRIBUTION PIPING SYSTEMS PRIOR TO USE.
- B. USE PURGING AND DISINFECTING PROCEDURE PRESCRIBED BY AUTHORITY HAVING JURISDICTION OR, IF A METHOD IS NOT PRESCRIBED BY THAT AUTHORITY, THE PROCEDURE DESCRIBED IN EITHER AWWA C651 OR AWWA C650R AS DESCRIBED BELOW:
1. FLUSH PIPING SYSTEM WITH CLEAN, POTABLE WATER UNTIL DIRTY WATER DOES NOT APPEAR AT OUTLETS.
 2. FILL SYSTEM OR PART THEREOF WITH WATER/CHLORINE SOLUTION CONTAINING AT LEAST 50 PARTS PER MILLION OF CHLORINE. ISOLATE (VALVE OFF) AND ALLOW TO STAND FOR 24 HOURS. PROVIDE PROPER SIGNAGE TO PREVENT ACCIDENTAL USE DURING DISINFECTION.
 3. DRAIN SYSTEM OR PART THERE OF OF PREVIOUS SOLUTION AND REFILL WITH WATER/CHLORINE SOLUTION CONTAINING AT LEAST 200 PARTS PER MILLION OF CHLORINE. ISOLATE AND ALLOW TO STAND FOR 3 HOURS.
 4. FLUSH SYSTEM WITH CLEAN, POTABLE WATER UNTIL CHLORINE DOES NOT REMAIN IN WATER COMING FROM SYSTEM FOLLOWING ALLOWED STANDING TIME.
- C. SUBMIT WATER SAMPLES IN STERILE BOTTLES TO AUTHORITY HAVING JURISDICTION. REPEAT PROCEDURE IF BIOLOGICAL EXAMINATION MADE BY THE AUTHORITY SHOWS EVIDENCE OF CONTAMINATION.
- D. PREPARE AND SUBMIT REPORTS FOR PURGING AND DISINFECTING ACTIVITIES.
- E. CLEAN INTERIOR OF PIPING SYSTEM. REMOVE DIRT AND DEBRIS AS WORK PROGRESSES.
- 3.05 AS-BUILT DRAWINGS
- A. UPON COMPLETION OF INSTALLATION, THE CONTRACTOR SHALL FURNISH TO THE ARCHITECT A SET OF DRAWINGS, MARKED TO SCALE, INDICATING THE SIZE AND LOCATION OF PIPING AND DUCTS, AND NOTING ALL MAJOR CHANGES MADE DURING CONSTRUCTION. THE CONTRACTOR SHALL OBTAIN THE DRAWINGS FROM THE ARCHITECT AND SHALL BEAR ALL COSTS IN OBTAINING THE DRAWINGS AND PROVIDING THE AS-BUILT DRAWINGS. THE CONTRACTOR SHALL DELIVER THE DRAWINGS PLUS TWO SETS OF AS-BUILT DRAWINGS TO THE ARCHITECT. EACH SHEET IN EACH SET SHALL BE SIGNED BY A PRINCIPAL REPRESENTATIVE OF THE CONTRACTOR, DATED AND HAVE "AS-BUILT" STAMPED NEAR THE SIGNATURE. DRAWINGS SHALL GIVE ACCURATE DIMENSIONS MEASURED FROM COLUMNS, WALLS, BEAMS AND OTHER FIXED PARTS OF THE BUILDING TO THE CONCEALED MATERIALS. THE CONTRACTOR SHALL MAINTAIN A SET OF DRAWINGS AT THE SITE AND EACH DAY SHALL RECORD INSTALLATION OF PIPE, DUCTS, ETC. TO INSURE ACCURATE "AS-BUILT" DRAWINGS. THE CONTRACTOR SHALL ALSO FURNISH A SET OF DRAWINGS AND TWO SETS OF CONTRACTOR SIGNED AND DATED AS-BUILT PRINTS OF THE CONTROLS.
- 3.06 GUARANTEE AND SERVICE
- A. IN ADDITION TO THE GUARANTEE OF EQUIPMENT BY THE MANUFACTURER OF EACH PIECE OF EQUIPMENT SPECIFIED HEREIN, THE MECHANICAL CONTRACTOR SHALL ALSO GUARANTEE SUCH EQUIPMENT AND SHALL BE HELD RESPONSIBLE FOR A PERIOD OF ONE YEAR FROM FINAL ACCEPTANCE FOR NECESSARY ADJUSTMENTS AND/OR REPLACEMENTS OF ALL DETECTIVE EQUIPMENT, MATERIALS AND WORKMANSHIP WITHOUT EXPENSE TO THE OWNER. PROVIDE A LETTER TO THE OWNER STATING THE CONTRACTOR'S GUARANTEE AND DATES OF GUARANTEE COVERAGE.
- 3.07 REMOVAL OF RUBBISH
- A. CONTRACTOR SHALL AT ALL TIMES KEEP PREMISES FREE FROM ACCUMULATIONS OF WASTE MATERIAL OR RUBBISH GENERATED BY WORK UNDER THIS CONTRACT.
- 3.08 EXCAVATION, BACKFILLING AND COMPACTION
- A. ALL EXCAVATION, BACKFILLING, COMPACTION, TESTING, ETC. REQUIRED FOR THE INSTALLATION OF UNDERGROUND PIPING IN THIS DIVISION OF THE SPECIFICATIONS SHALL BE DONE BY THE PLUMBING CONTRACTOR. THIS WORK SHALL BE DONE IN STRICT ACCORDANCE WITH EXCAVATION AND BACKFILLING SECTION OF DIVISION 2.




10175 Fortune Parkway, Suite 701
Jacksonville, FL 32256
p 904.683.9201 f 904.683.9702

www.kasperarch.com
FL License No.: AA26000802



formerly McVigh & Mangum Engineering
www.IMEGcorp.com
9133 E. C. Simpson Parkway
Jacksonville, Florida 32256
Ph: (904) 483-5700 Fax: (904) 486-0700
email: msh@McVighMangum.com
CA 630
Eng. of Record: David D. Dowell
License No.: 78366

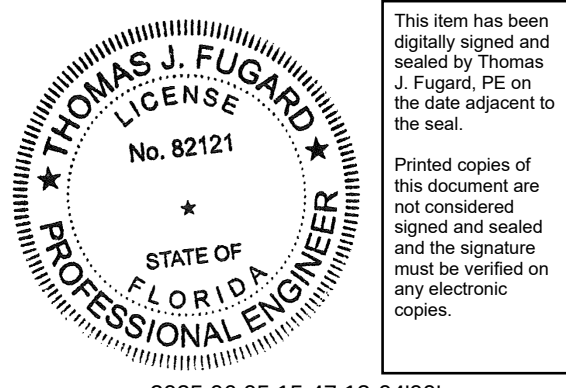

This item has been digitally signed and sealed by Thomas J. Fugard, PE on the date adjacent to the seal.
Printed copies of this document are not considered signed and sealed and the signature must be verified on any electronic copies.

2025.06.05 15:47:13 -0400

BUSY BEE
ELLISVILLE

136 SW WEBBS GLN
LAKE CITY, FL 32024

PROJECT NO.: 22024

DATE: 04/10/2025

PRIOR ISSUES:

SPECIFICATIONS

P7.1

DRAWN BY: DD
CHECKED BY: TF

DESIGN DEVELOPMENT

NOT FOR CONSTRUCTION