

EQUIPOTENTIAL BONDING GRID:

ALL METAL PARTS SPECIFIED IN 680.26(B) MUST BE BONDED TO AN EQUIPOTENTIAL BONDING GRID WITH A SOLID COPPER CONDUCTOR NOT SMALL THAN 8 AWG. THE TERMINATION OF THE BONDING CONDUCTOR MUST BE MADE BY EXOTHERMIC WELDING, LISTED PRESSURE CONNECTORS, OR LISTED CLAMPS THAT ARE LABELED AS SUITABLE FOR THE PURPOSE. THE QUIPOTENTIAL BONDING GRID MUST EXTEND UNDER PAVED WALKING SURFACES FOR 3 FEET HORIZONTALLY FROM THE WATER (680.26(C)).

THE EQUIPOTENTIAL BONDING GRID MUST BE FORMED FROM EITHER OR BOTH OF:

THE STRUCTURAL REINFORCING STEEL OF A CONCERTE PERMANENTLY INSTALLED POOL, OUTDOOR SPA, OR OUTDOOR HOT TUB, TIED TOGETHER BY THE USUAL STEEL TIE WIRES.

THE METAL WALLS OF A PERMANENTLY INSTALLED POOL, OUTDOOR SPA, OR OUTDOOR HOT TUB



THE EQUIPOTENTIAL BONDING GRID CAN BE CONSTRUCTED WITH 8 AWG BARE SOLID COPPER CONDUCTORS BONDED TO EA OTHER AT ALL POINTS OF CROSSING BY EXOTHERMIC WELDING, LISTED PRESSURE CONNECTORS OF THE SET SCREW OR COMPRESSION TYPE, LISTED CLAMPS, OR OTHER LISTED FITTINGS (250.8).

THE EQUIPOTENTIAL BONDING GRID MUST COVER THE CONTOUR OF THE PERMANENTLY INSTALLED POOL, OUTDOOR SPA OR HOT TUB AND DECK EXTENDING 3 FEET HORIZONTALLY FROM THE WATER. THE EQUIPOTENTIAL BONDING GRID MUST BE ARRANGED IN A 1-FOOT BY 1-FOOT NETWORK OF 8 AWG CONDUCTORS, WITH A TOLERANCE OF 4 INCHES.


EXCEPTION: THE EQUIPOTENTIAL BONDING GRID SHALL NOT BE REQ'D TO BE INSTALLED UNDER THE BOTTOM OR VERTICALLY ALONG THE WALLS OF VINYL LINED POLYMER WALL, FIBERGLASS COMPOSITE, OR OTHER POOLS CONSTRUCTED OF NON-CONDUCTIVE MATERIALS.

ANY METAL PARTS OF THE POOL, INCLUDING METAL STRUCTURAL SUPPORTS, SHALL BE BONDED IN ACCORDANCE WITH 680.26(B). POURED CONCRETE, PNEUMATICALLY-APPLIED CONCRETE, AND CONCRETE BLOCK SHALL BE CONSIDERED CONDUCTIVE MATERIAL


- GENERAL NOTES:
- 1) Per UL listing, pool motors require GFCI protection
  - 2) FSPA requires the motor controller to be capable of 2 speeds, a time clock will not satisfy this unless it has 2 trip settings.
  - 3) If heater installed (other than solar), it must comply with FBC-EC403.9.1 & have a cover per 403.9.3 (this applies to mechanical (not solar) heaters---cover required)
  - 4) Outdoor swimming pools shall be provided with a barrier complying with Sections R4501.17.1.1 through R4501.17.1.14.
  - 5) NEC 680.26(C) requires a conductive metal part of 9 sq., in. in direct contact with the pool water.
  - 6) R4501.17.1.9 All doors and windows providing direct access from the home to the pool shall be equipped with an exit alarm complying with UL 2017 that has a minimum sound pressure rating of 85 dB at 10 feet.

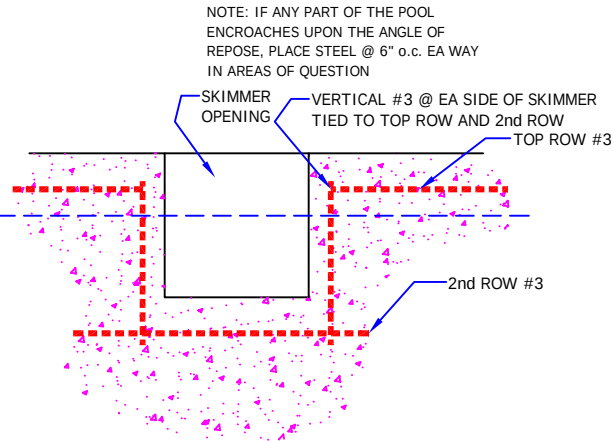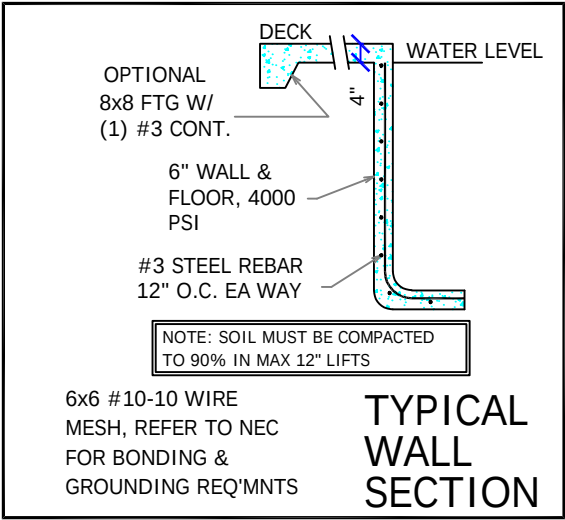

SKIMMER OPENING DETAIL

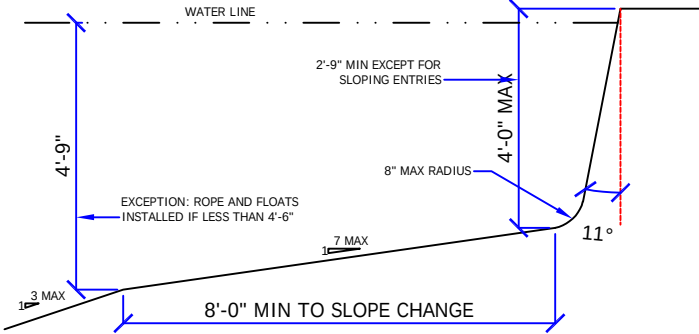

FLOOR SLOPE DETAIL

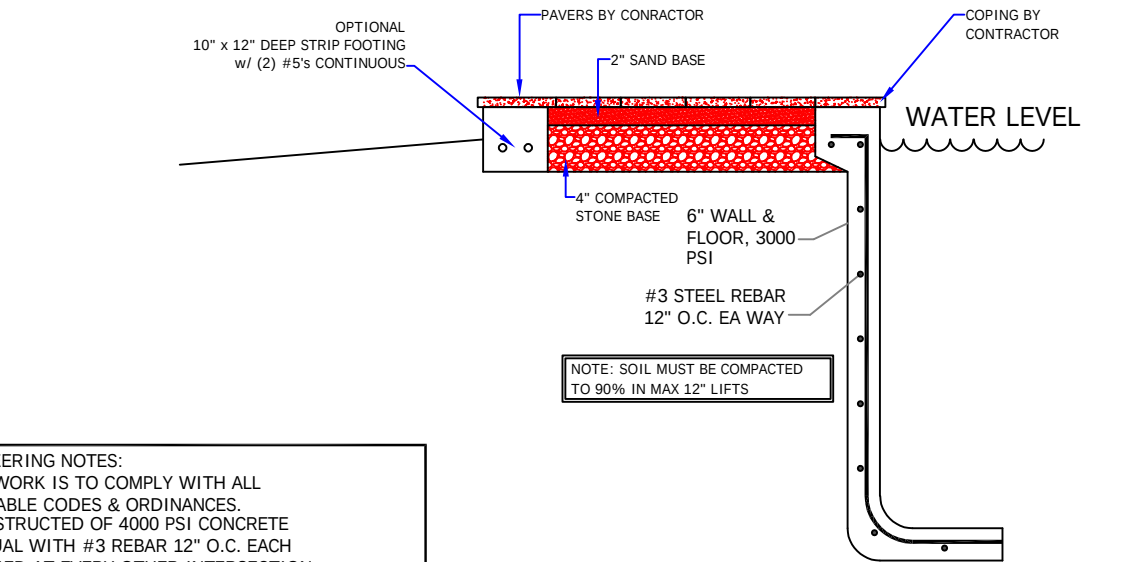

ALTERNATIVE WALL SECTION


- ENGINEERING NOTES:
1. ALL WORK IS TO COMPLY WITH ALL APPLICABLE CODES & ORDINANCES.
  2. CONSTRUCTED OF 4000 PSI CONCRETE OR EQUAL WITH #3 REBAR 12" O.C. EACH WAY, TIED AT EVERY OTHER INTERSECTION. MIN COVER FOR REBAR IS 2.5" MIN OVERLAP IS 18".
  3. N/A

4. ASSUMED SOIL BEARING = 2 KSF
5. CIRCULATION SYSTEMS, COMPONENTS, & EQUIPMENT SHALL COMPLY W/ NSF 50.
6. INSTALL CONTROL JOINTS @ 20'-0" ON CENTER IN POOL DECKING.
7. PLANS TO CONFORM TO NEC 2020
8. 2023 FBC RESIDENTIAL 8th EDITION APSP13
9. CONCRETE STAIRS ARE 12" TREAD WIDTH AND 10" MAXIMUM HEIGHT
10. ALL CONSTRUCTION SHALL COMPLY WITH ANSI 5-03, 2020 NEC ARTICLE 680, & ANSI-NSPI 3-99 IN-GROUND SPA CONSTR.


\*11. ENGINEERS DESIGN IS FOR STRUCTURAL ONLY. DESIGN OF PIPING/EQUIPMENT ETC.

BY POOL CONTRACTOR


- FENCE REQUIREMENTS:
1. MINIMUM 48" HEIGHT
  2. 2" MAX VERTICAL CLEARANCE BETWEEN GRADE & BARRIER BOTTOM.
  3. MAX OPENING SHALL NOT ALLOW PASSAGE OF 4" SPHERE.
  4. FENCE POSTS WILL BE LOCATED ON POOL-SIDE OF FENCE.
  5. GATE WILL BE SELF-LOCKING WITH APPROVED LOCKING DEVICE.

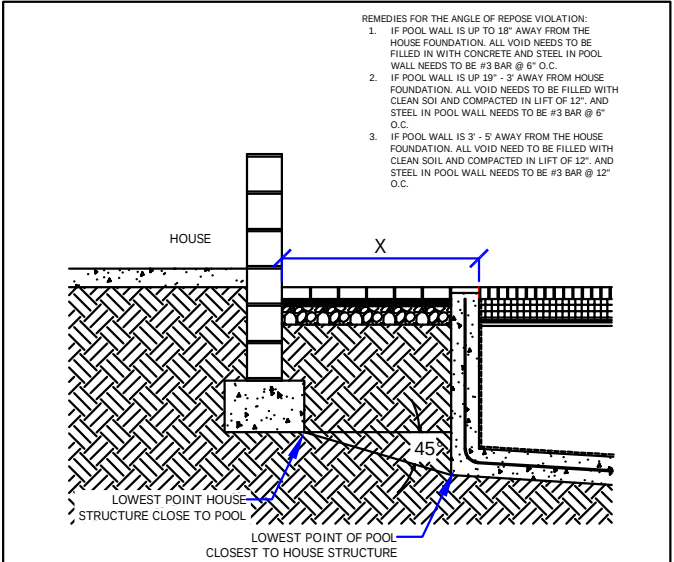

ANGLE OF REPOSE

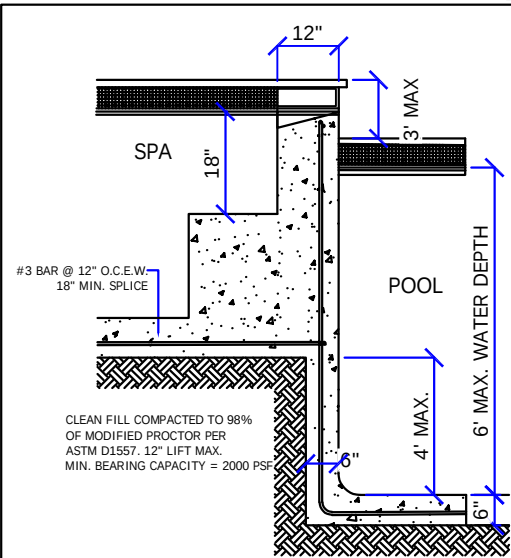

POOL / SPA COMMON WALL DETAIL

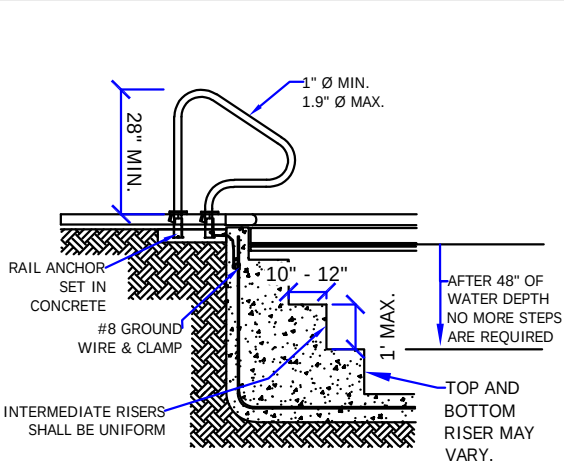

POOL STAIRS DETAIL

Riddle Consulting Engineers, Inc.




Paul D. Riddle, P.E.  
Senior Engineer  
COA: 00004759

ADDRESS 1720 SE CTY HWY 484  
BELLEVUE, FL 34420  
PHONE (352) 245-7041  
FAX (352) 245-5458  
WEB: WWW.RIDDLEENGINEERING.COM

ENGINEER'S SEAL

IGC  
CA 2  
Digital Signer:IGC  
CA 2  
DN:CN=PAUL D RIDDLE,  
dnQualifier=A0141  
OC0000019B6BE1  
CC12001F34E4,  
O=Unaffiliated,  
C=US  
Date:2026.08.10  
10:45:56 -04:00

PAUL D. RIDDLE, P.E.  
P.E. 36989

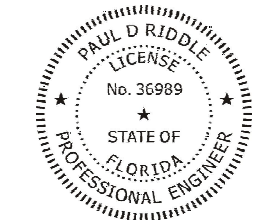

THIS ITEM HAS BEEN DIGITALLY SIGNED AND SEALED BY PAUL D. RIDDLE, PE ON THE DATE ADJACENT TO THE SEAL. PRINTED COPIES OF THIS DOCUMENT ARE NOT CONSIDERED SIGNED AND SEALED AND THE SIGNATURE MUST BE VERIFIED ON ANY ELECTRONIC COPIES.

JOB No.: 2250048


DATE Aug. 10, 26

A CUSTOM DESIGN FOR  
THE SPARKS  
RESIDENCE  
AQUATIC ART POOLS AND SPAS

Page:

1 of 4

3/16" = 1'-0" SCALE

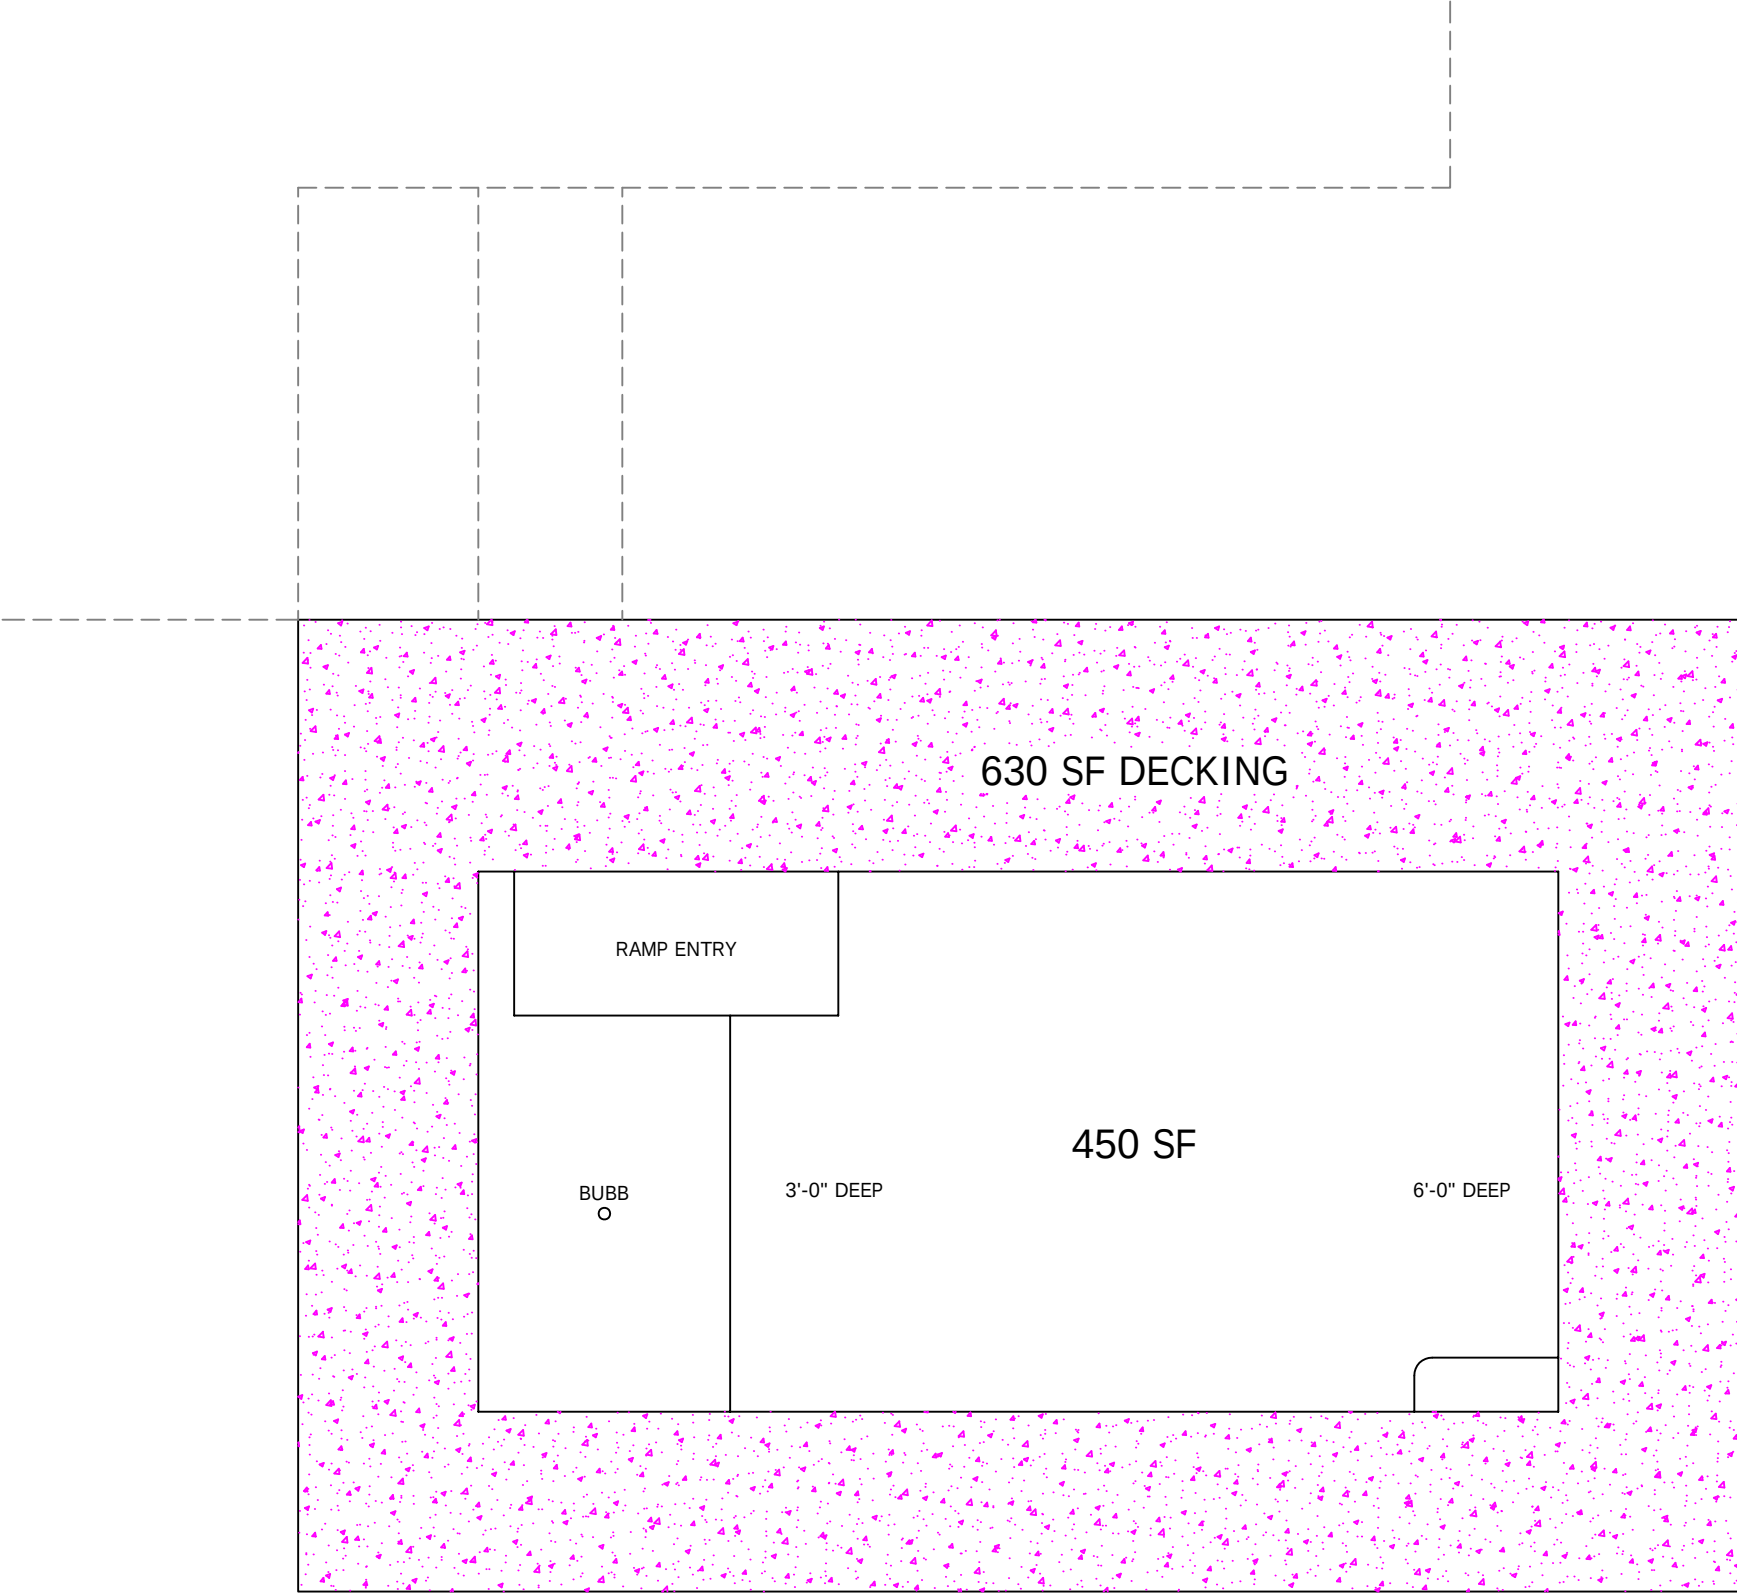

Riddle Consulting Engineers, Inc.



Paul D. Riddle, P.E.  
Senior Engineer  
COA: 00004759


ADDRESS 1720 SE CTY HWY 484  
BELLEVUE, FL 34420  
PHONE (352) 245-7041  
FAX (352) 245-5458  
WEB: [WWW.RIDDLEENGINEERING.COM](http://WWW.RIDDLEENGINEERING.COM)

ENGINEER'S SEAL

IGC  
CA 2

Digital Signer:IGC  
CA 2  
DN:CN=PAUL D  
RIDDLE,  
dnQualifier=A0141  
0C0000019B6BE1  
CC12001F34E4,  
O=Unaffiliated,  
C=US  
Date:2026.08.10  
10:45:56 -04:00

PAUL D. RIDDLE, P.E.  
P.E. 36989

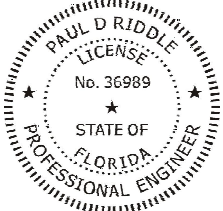

THIS ITEM HAS BEEN DIGITALLY  
SIGNED AND SEALED BY PAUL D.  
RIDDLE, PE ON THE DATE ADJACENT TO  
THE SEAL. PRINTED COPIES OF THIS  
DOCUMENT ARE NOT CONSIDERED  
SIGNED AND SEALED AND THE  
SIGNATURE MUST BE VERIFIED ON ANY  
ELECTRONIC COPIES.

JOB No.:

DATE Aug. 10, 26



A CUSTOM DESIGN FOR  
THE SPARKS  
RESIDENCE  
AQUATIC ART POOLS AND SPAS

Page:

2 of 4

3/16" = 1'-0" SCALE

PIPING KEY

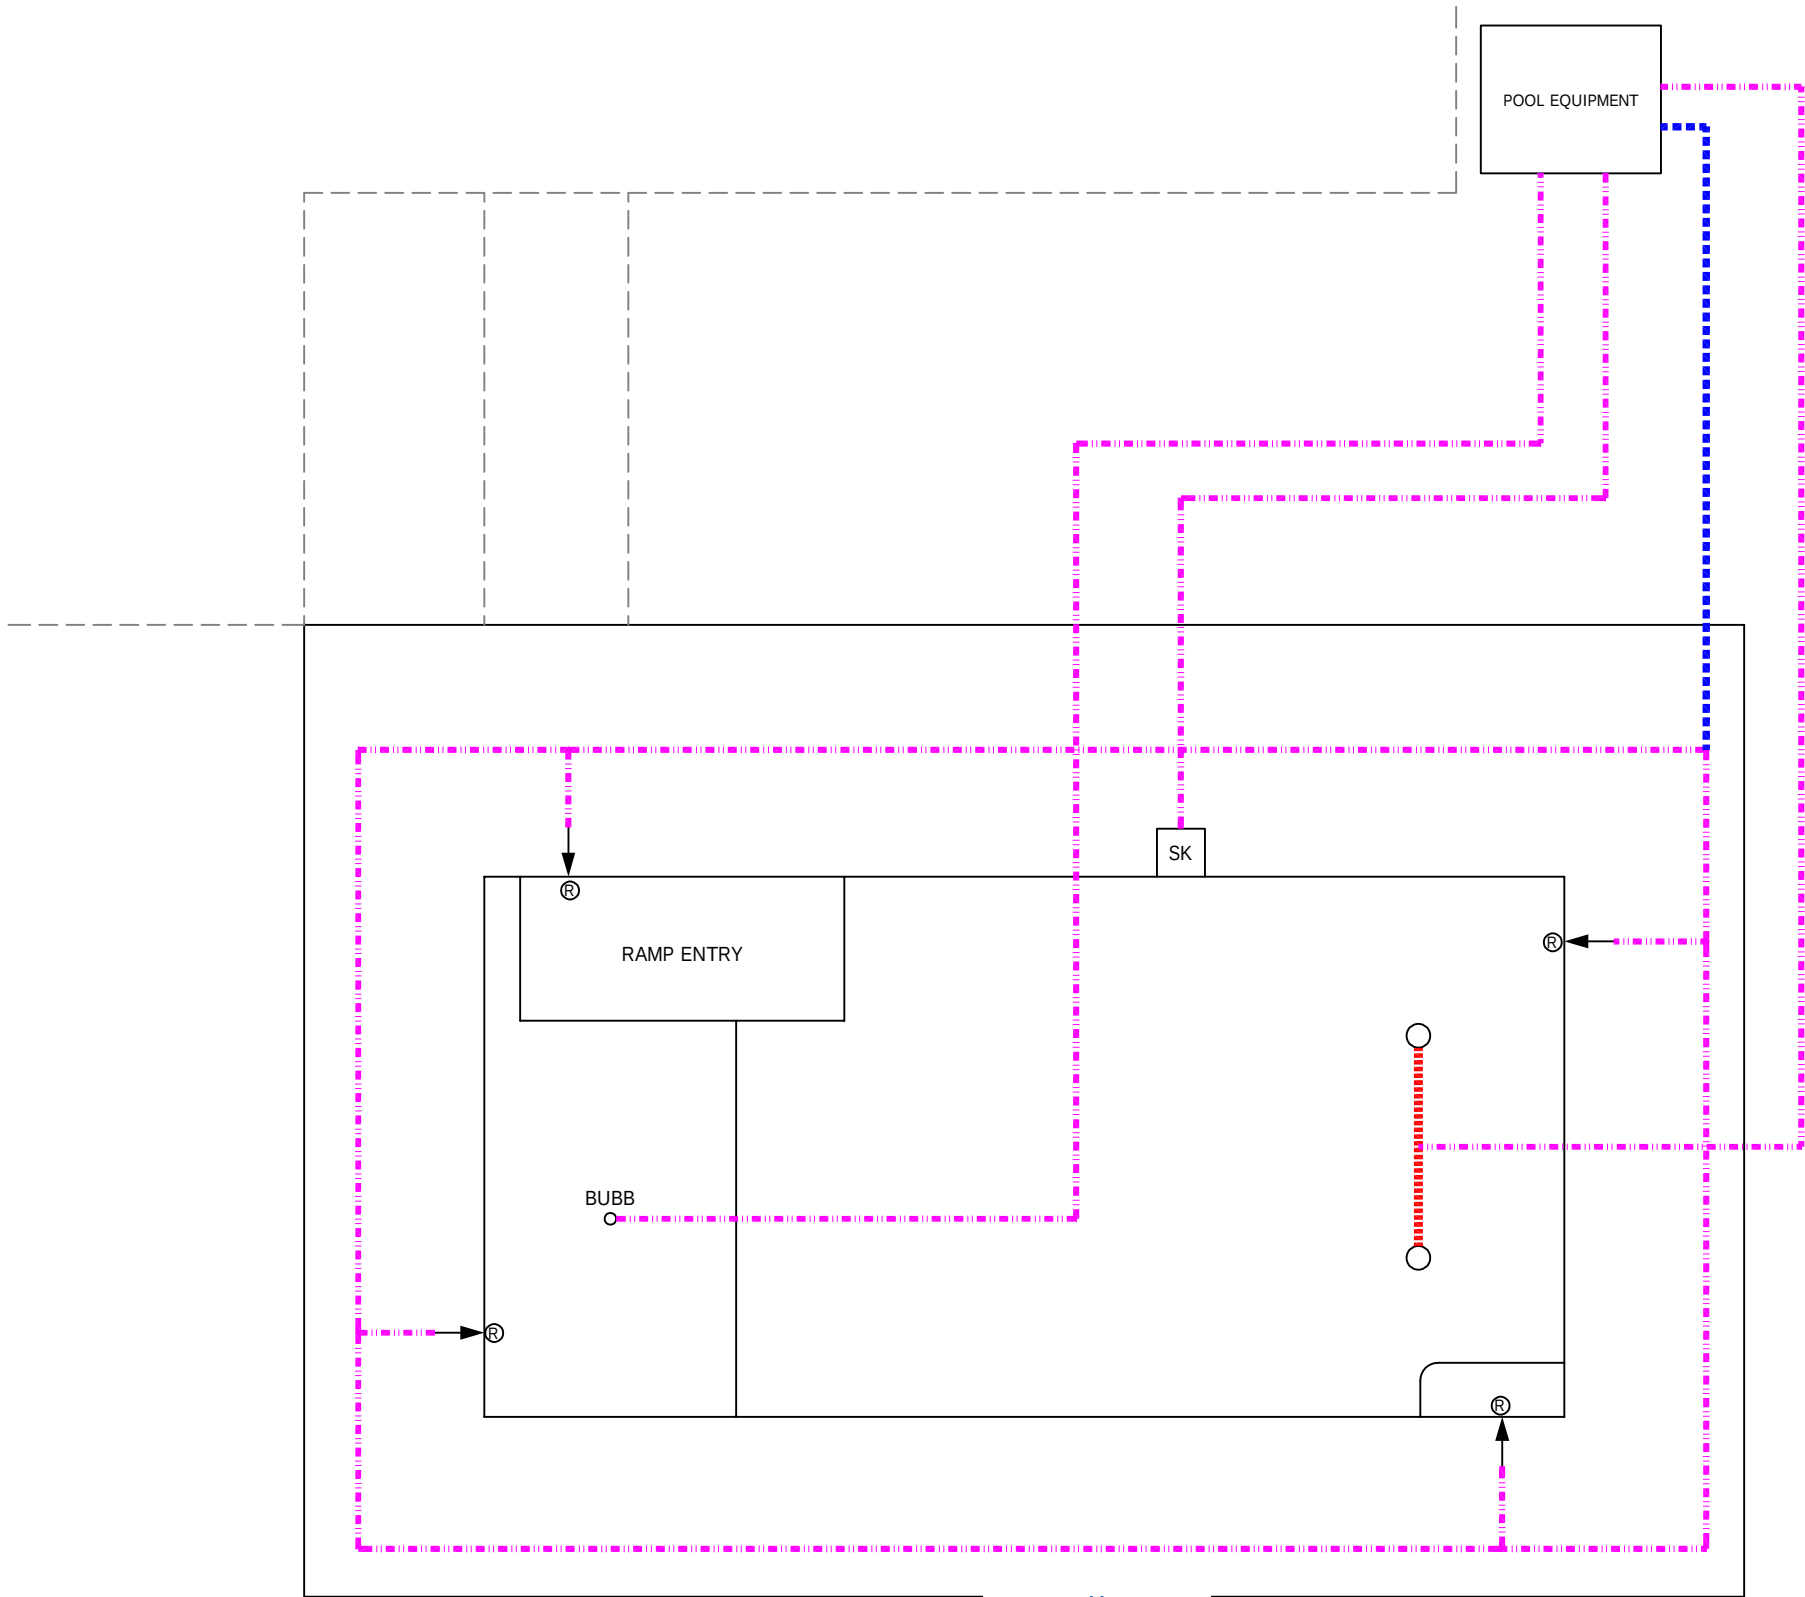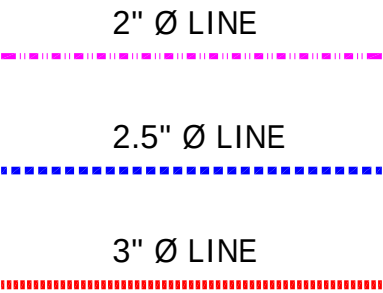

Riddle Consulting Engineers, Inc.



Paul D. Riddle, P.E.  
Senior Engineer  
COA: 00004759


ADDRESS 1720 SE CTY HWY 484  
BELLEVUE, FL 34420  
PHONE (352) 245-7041  
FAX (352) 245-5458  
WEB: WWW.RIDDLEENGINEERING.COM

ENGINEER'S SEAL

IGC  
CA 2

Digital Signer: IGC  
CA 2  
DN: CN=PAUL D RIDDLE,  
dnQualifier=A0141  
0C0000019B6BE1  
CC12001F34E4,  
O=Unaffiliated,  
C=US  
Date: 2026.08.10  
10:45:56 -04:00

PAUL D. RIDDLE, P.E.  
P.E. 36989

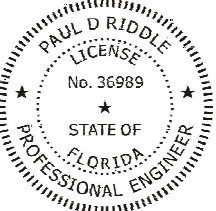

THIS ITEM HAS BEEN DIGITALLY  
SIGNED AND SEALED BY PAUL D.  
RIDDLE, PE ON THE DATE ADJACENT TO  
THE SEAL. PRINTED COPIES OF THIS  
DOCUMENT ARE NOT CONSIDERED  
SIGNED AND SEALED AND THE  
SIGNATURE MUST BE VERIFIED ON ANY  
ELECTRONIC COPIES.

JOB No.:

DATE Aug. 10, 26

A CUSTOM DESIGN FOR  
THE SPARKS  
RESIDENCE  
AQUATIC ART POOLS AND SPAS

Page:


3 of 4

3/16" = 1'-0" SCALE

SPECIFICATIONS

| Model No.   | THP  | WEF <sup>3</sup> | Voltage | Max Watts | Amps | Union Size | Rec. Pipe Size <sup>4</sup> | Carton Weight | Overall Length |
|-------------|------|------------------|---------|-----------|------|------------|-----------------------------|---------------|----------------|
| VSFHP165JEP | 1.65 | 9.118            | 230VAC  | 1,600 W   | 10.5 | 2" x 2"    | 1 1/2 - 2 1/2"              | 46 lbs        | 24"            |
| VSFHP165AUT |      |                  |         |           |      |            |                             |               |                |
| VSFHP085JEP | 0.85 | 11.900           | 115VAC  | 975 W     | 10.0 | 2" x 2"    | 1 1/2 - 2"                  | 46 lbs        | 24"            |
| VSFHP085AUT |      |                  |         |           |      |            |                             |               |                |

PERFORMANCE

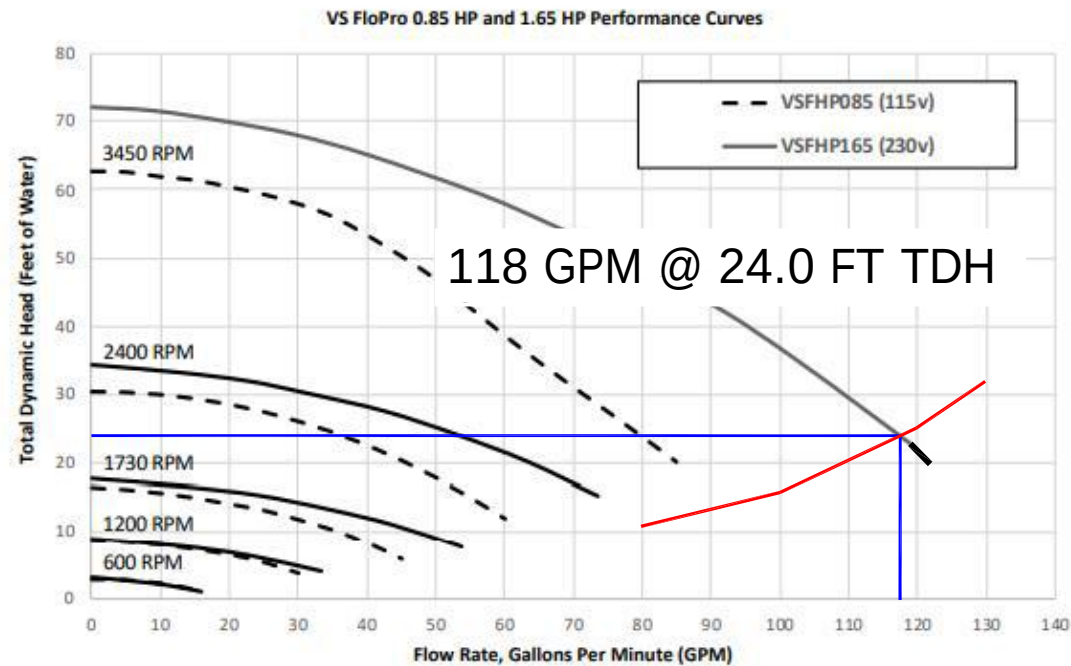

AQUATIC ART  
8/10/2026

SPARKS POOL

MINIMUM FLOW REQ'D = 62.08 GPM  
POOL VOLUME : SURFACE AREA X AVG DEPTH X 7.48 GAL / CF  
VOL = 450 SF X 4.5 FT DEEP 15147 Gallons  
TURNOVER TIME: No. Hours X 60 min / h c e  
6 hours x 60 = 360 minutes  
MAX POOL FLOW RATE: GALLONS / TURNOVER = FLOW RATE  
15147 GAL / 360 minutes = 42.075 GPM

POOL FEATURES  
JETS, SHEER DE 1 WATER FEATURE GPM EA = 20 GPM  
TOTAL SUGGESTED POOL FLOW RATE: 62.08 GPM

V = 1.318 C R<sup>0.63</sup> S<sup>0.54</sup>  
SUPPLY (RETURN) PIPING  
2.5 in = NOMINAL DIAMETER  
2.45 in = D ACTUAL diam  
0.2038 ft = D diam  
140 = C, coefficient of roughness  
4.6951 in<sup>2</sup> = A pipe  
0.0326 ft<sup>2</sup> = A pipe  
118.00 gpm / line 0.2629234 cfs  
118.00 gpm = TOTAL FLOW IN 1 LINES  
0.2629 cfs = Q flow M  
8.0639 f/sec = V = Velocity  
0.0509 ft = R = Hydraulic Radius = A / P

SUCTION PIPING  
2 in = NOMINAL DIAMETER  
2.05 in = D ACTUAL diam  
0.1706 ft = D diam  
140 = C, coefficient of roughness  
3.2910 in<sup>2</sup> = A pipe  
0.0229 ft<sup>2</sup> = A pipe  
59.00 gpm = 0.1314617 cfs  
2 No of Suction Pipes  
0.1315 cfs = Q flow rate  
5.7522 f/sec = V = Velocity  
0.0426 ft = R = Hydraulic Radius = A / P

0.0979 ft/ft = S hydraulic gradient  
18 ft = pipe length average  
1.76 ft = hf = head loss due to friction  
0.76 psi  
0.00763

0.0644 ft/ft = S hydraulic gradient  
37 ft = pipe length average  
2.38 ft = hf = head loss due to friction  
1.03 psi  
0.0103227

| BRANCH P model             | FLOW GPM       | STR FT | FT   | PSI   |
|----------------------------|----------------|--------|------|-------|
| 2 in @ 6 fps max BRANCH =  | 61.54 GPM      |        |      |       |
| 2 in @ 8 fps max TRUNK =   | 82.06 GPM      | 80.00  | 11.0 | 4.76  |
| 2 in @ 10 fps max RETURN = | 102.57 GPM     | 100.00 | 16.8 | 7.27  |
| 3 in @ 3 fps max RETURN =  | 67.95 GPM MAIN | 120.00 | 25.4 | 11.00 |
|                            | DRAIN          | 130.00 | 31.6 | 13.68 |
|                            |                | 140.00 | 38.1 | 16.49 |

OTHER PRESSURE LOSSES per mnfg  
6.98 FT = FILTER TDH LOSS  
FT = HEATER TDH LOSS  
6.98 FT = TOTAL TDH LOSS  
JANDY PRO SERIES CS150-250 CARTRIDGE FILTER

| MINOR LOSSES (SUPPLY & SUCTION COMBINED) | K     | h (lost) ft | FT   | PSI         |
|------------------------------------------|-------|-------------|------|-------------|
| h (lost) = KL * V <sup>2</sup> / (2*g)   |       |             |      |             |
| 2 ea = # tees thru side outlet           | 1.75  | 3.53        |      |             |
| 2 ea = # gate valves                     | 1     | 2.02        |      |             |
| 1 ea = # check valves                    | 0.2   | 0.20        |      |             |
| 0 THERAPY JET                            | 21.73 | 0.00        |      |             |
| 0 ea = # 45 deg ELL                      | 0.4   | 0.00        |      |             |
| 6 ea = # 90 deg ELL                      | 0.75  | 4.54        |      |             |
| 0 ea = Reducer D2=                       | 0.5   | 0.0871791   | 0.00 | D1/D2= 4.89 |
| TOTAL =                                  |       | 10.30 ft    |      |             |

ELEVATION DIFFERENCE  
0.00 ft = delta Z  
model  
2.57 FT = TOTAL FRICTION HEAD LOSS AFTER SPLIT @ LOOP  
23.99 FT = TOTAL HEAD LOSS IN SYSTEM @ 118.00 GPM  
10.39 PSI

PUMP SELECTION : JANDY 1.65 VS PUMP  
model: VARIABLE SPEED  
SUCTION OUTLET COVER: MUST EXCEED 118.00 GPM FLOW RATE  
model 32" CHANNEL DRAIN OR 2 OUTLET COVERS

SYSTEM FLOW RATE MUST NOT EXCEED APPROVED COVER FLOW RATE O.K.  
PER FBC 2023 8TH EDITION ANSI / APSP 13  
MOTOR TO BE GFCI PROTECTED PER NEC 680.21©

Riddle Consulting  
Engineers, Inc.



Paul D. Riddle, P.E.  
Senior Engineer  
COA: 00004759


ADDRESS 1720 SE CTY HWY 484  
BELLEVUE, FL 34420  
PHONE (352) 245-7041  
FAX (352) 245-5458  
WEB: WWW.RIDDLEENGINEERING.COM

ENGINEER'S SEAL

IGC  
CA 2

Digital Signer:IGC  
CA 2  
DN:CN=PAUL D  
RIDDLE,  
dnQualifier=A0141  
0C0000019B6BE1  
CC12001F34E4,  
O=Unaffiliated,  
C=US  
Date:2026.08.10  
10:45:56 -04:00

PAUL D. RIDDLE, P.E.  
P.E. 36989

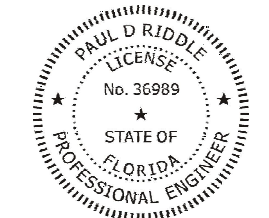

THIS ITEM HAS BEEN DIGITALLY  
SIGNED AND SEALED BY PAUL D.  
RIDDLE, PE ON THE DATE ADJACENT TO  
THE SEAL. PRINTED COPIES OF THIS  
DOCUMENT ARE NOT CONSIDERED  
SIGNED AND SEALED AND THE  
SIGNATURE MUST BE VERIFIED ON ANY  
ELECTRONIC COPIES.

JOB No.:

DATE Aug. 10, 26

A CUSTOM DESIGN FOR  
THE SPARKS  
RESIDENCE  
AQUATIC ART POOLS AND SPAS

Page:

4 of 4

3/16" = 1'-0" SCALE