

76 North Meadowbrook Drive Alpine, UT 84004 office (201) 874-3483 swyssling@wysslingconsulting.com

October 25, 2022

Lumio Solar 12600 Challenger Parkway, Suite 200 Orlando, FL 32826

Scott

Digitally signed by Scott Wyssling, PE
DN: C=US, S=Utah, L=Alpine, O=Wyssling
Consulting, OU=Engineering, CN='Scott Wyssling,
PE', E=swyssling@wysslingconsulting.com
Reason: I am the author of this document
Location: your signing location here
Date: 2022.10.25 13:28:35-06'00'
Foxit PDF Editor Version: 11.1.0

Re: Engineering Services Teders Residence 875 Northwest Country Lake Drive, Lake City FL 14.800 kW System

To Whom It May Concern:

We have received information regarding solar panel installation on the roof of the above referenced structure. Our evaluation of the structure is to verify the existing capacity of the roof system and its ability to support the additional loads imposed by the proposed solar system.

A. Site Assessment Information

- 1. Site visit documentation identifying attic information including size and spacing of framing for the existing roof structure.
- Design drawings of the proposed system including a site plan, roof plan and connection details for the solar panels. This information will be utilized for approval and construction of the proposed system.

B. Description of Structure:

Roof Framing: Prefabricated wood trusses at 24" on center. All truss members are

constructed of 2 x 4 dimensional lumber.

Roof Material: Composite Asphalt Shingles

Roof Slopes: 27 +/- degrees Attic Access: Accessible Foundation: Permanent

C. Loading Criteria Used

Dead Load

- Existing Roofing and framing = 7 psf
- New Solar Panels and Racking = 3 psf
- TOTAL = 10 PSF
- **Live Load** = 20 psf (reducible) -0 psf at locations of solar panels
- Ground Snow Load = 0 psf
- Wind Load based on ASCE 7-16
 - Ultimate Wind Speed = 120 mph (based on Risk Category II)
 - Exposure Category B

Analysis performed of the existing roof structure utilizing the above loading criteria is in accordance with the FBC 2020 7th Edition, including provisions allowing existing structures to not require strengthening if the new loads do not exceed existing design loads by 105% for gravity elements and 110% for seismic elements. This analysis indicates that the existing framing will support the additional panel loading without damage, if installed correctly.

D. Solar Panel Anchorage

- 1. The solar panels shall be mounted in accordance with the most recent Unirac installation manual. If during solar panel installation, the roof framing members appear unstable or deflect non-uniformly, our office should be notified before proceeding with the installation.
- 2. The maximum allowable withdrawal force for a #14 lag screw is 246 lbs per inch of penetration as identified in the National Design Standards (NDS) of timber construction specifications. Based on two screws with a minimum penetration depth of 1½", the allowable capacity per connection is greater than the design withdrawal force (demand). Considering the variable factors for the existing roof framing and installation tolerances, the connection using two #14 lag screw with a minimum of 1½" embedment will be adequate and will include a sufficient factor of safety.
- 3. Considering the wind speed, roof slopes, size and spacing of framing members, and condition of the roof, the panel supports shall be placed no greater than 48" on center.
- 4. Panel supports connections shall be staggered to distribute load to adjacent framing members.

Based on the above evaluation, this office certifies that with the racking and mounting specified, the existing roof system will adequately support the additional loading imposed by the solar system. This evaluation is in conformance with the *FBC 2020 7th Edition*, current industry standards and practice, and is based on information supplied to us at the time of this report.

Should you have any questions regarding the above or if you require further information do not hesitate to contact me.

Scott E. Wyssling, PE

Florida License No. 815



Date Signed 10/25/2022





SCOPE OF WORK:

TO INSTALL A ROOF MOUNTED SOLAR PHOTOVOLTAIC SYSTEM AT THE OWNER RESIDENCE LOCATED AT 875 NORTHWEST COUNTRY LAKE DRIVE, LAKE CITY, FL 32055.

SYSTEM DC RATING: 14.80 KWDC SYSTEM AC RATING: 10.74 KWAC

GENERAL NOTES:

- THESE CONSTRUCTION DOCUMENTS HAVE BEEN BASED ON FIELD INSPECTIONS AND OTHER INFORMATION AVAILABLE AT THE TIME. ACTUAL FIELD CONDITIONS MAY REQUIRE MODIFICATIONS IN CONSTRUCTION DETAILS.
- CONTRACTOR HAS THE FULL RESPONSIBILITY TO CHECK AND VERIFY ALL DIMENSIONS AND EXISTING CONDITIONS. ANY DISCREPANCIES SHALL BE REPORTED TO THE ENGINEER BEFORE PROCEEDING WITH THE WORK. ANY WORK STARTED BEFORE CONSULTATION AND ACCEPTANCE BY THE ENGINEER SHALL BE THE SOLE RESPONSIBILITY OF THE CONTRACTOR AND SHALL BE SUBJECT TO CORRECTION BY THEM WITHOUT ADDITIONAL COMPENSATION.
- THE CONTRACTOR SHALL BE HELD RESPONSIBLE FOR THE PROPER INSTALLATION AND COMPLETION OF THE WORK WITH APPROVED MATERIALS.
- THE EQUIPMENT AND ALL ASSOCIATED WIRING AND INTERCONNECTION SHALL BE INSTALLED ONLY BY QUALIFIED PEOPLE. A QUALIFIED PERSON IS ONE WHO HAS SKILLS AND KNOWLEDGE RELATED TO THE CONSTRUCTION AND OPERATION OF THE ELECTRICAL EQUIPMENT AND INSTALLATIONS AND HAS RECEIVED SAFETY TRAINING TO RECOGNIZE AND AVOID THE HAZARDS INVOLVED. (NEC 690.4(C), NEC 2017).
- NEW CONDUIT ROUTING SHOWN IS ESSENTIALLY SCHEMATIC. CONTRACTOR SHALL LAY OUT RUNS TO SUIT FIELD CONDITIONS AND THE COORDINATION REQUIREMENTS OF OTHER TRADES.
- ARRAY WIRING SHOULD NOT BE READILY ACCESSIBLE EXCEPT TO QUALIFIED PERSONNEL.
- THE AC DISCONNECT MUST BE ACCESSIBLE TO QUALIFIED UTILITY PERSONNEL, BE LOCKABLE, AND BE A VISIBLE-BREAK SWITCH.

| SHEET INDEX | | | | | |
|------------------------|-----------------------------|--|--|--|--|
| CS-0 COVER SHEET & BOM | | | | | |
| E-1 | STRING LAYOUT & SIGNAGE | | | | |
| E-2 | ELECTRICAL DIAGRAM & CALCS. | | | | |
| E-3+ | EQUIPMENT SPECIFICATIONS | | | | |

GOVERNING CODES

2018 NFPA 1 (FIRE CODE)


2020 FFPC (7TH EDITION)

2017 NATIONAL ELECTRICAL CODE

2020 FLORIDA BUILDING CODE (7TH EDITION)

AUTHORITY HAVING JURISDICTION (AHJ): COLUMBIA COUNTY

| BILL OF MATERIALS | | | | | | | |
|-------------------|-----|---|--|--|--|--|--|
| EQUIPMENT | QTY | DESCRIPTION | | | | | |
| SOLAR PV MODULE | 37 | Q.PEAK DUO BLK ML-G10+ 400W | | | | | |
| MICROINVERTER | 37 | ENPHASE IQ8PLUS-72-2-US | | | | | |
| JUNCTION BOX | 1 | JUNCTION BOX, NEMA 3R, UL LISTED | | | | | |
| COMBINER BOX | 1 | ENPHASE IQ COMBINER 4/4C W/ IQ ENVOY (X-IQ-AM1-240-4) | | | | | |
| AC DISCONNECT | 1 | FUSED AC DISCONNECT, 240V, NEMA 3R, UL LISTED | | | | | |
| POWER PERFECT BOX | 1 | (ES1PN), 120V/240V, NEMA 3X | | | | | |
| | | | | | | | |

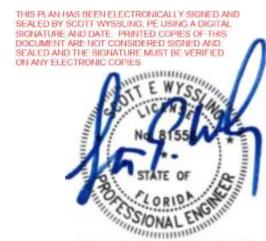

Wyssling Consulting, PLLC 76 N Meadowbrook Drive Alpine UT 84004 Florida License # RY34912

Date Signed 10/25/2022

THIS ITEM HAS BEEN DIGITALLY SIGNED AND SEALED BY SCOTT WYSSLING ON THE DATE ADJACENT TO THE SEAL. PRINTED COPIES OF THIS DOCUMENT ARE NOT CONSIDERED SIGNED AND SEAL, AND THE SIGNATURE MUST BE VERIFIED ON ANY ELECTRONIC COPIES



ATLANTIC KEY ENERGY LLC 7006 STAPOINT CT WINTER PARK, FL 32792

+1 (407) 988-0273

PROJECT NAME & ADDRESS

MARK TEDERS RESIDENCE 875 NORTHWEST COUNTRY LAKE DRIVE LAKE CITY,

SIGNATURE WITH SEAL

REVISIONS DESCRIPTION DATE REV Drawn by:

Checked by:


SHEET NAME

COVER SHEET & BOM

S.W.

10/21/22


SHEET NUMBER CS-0

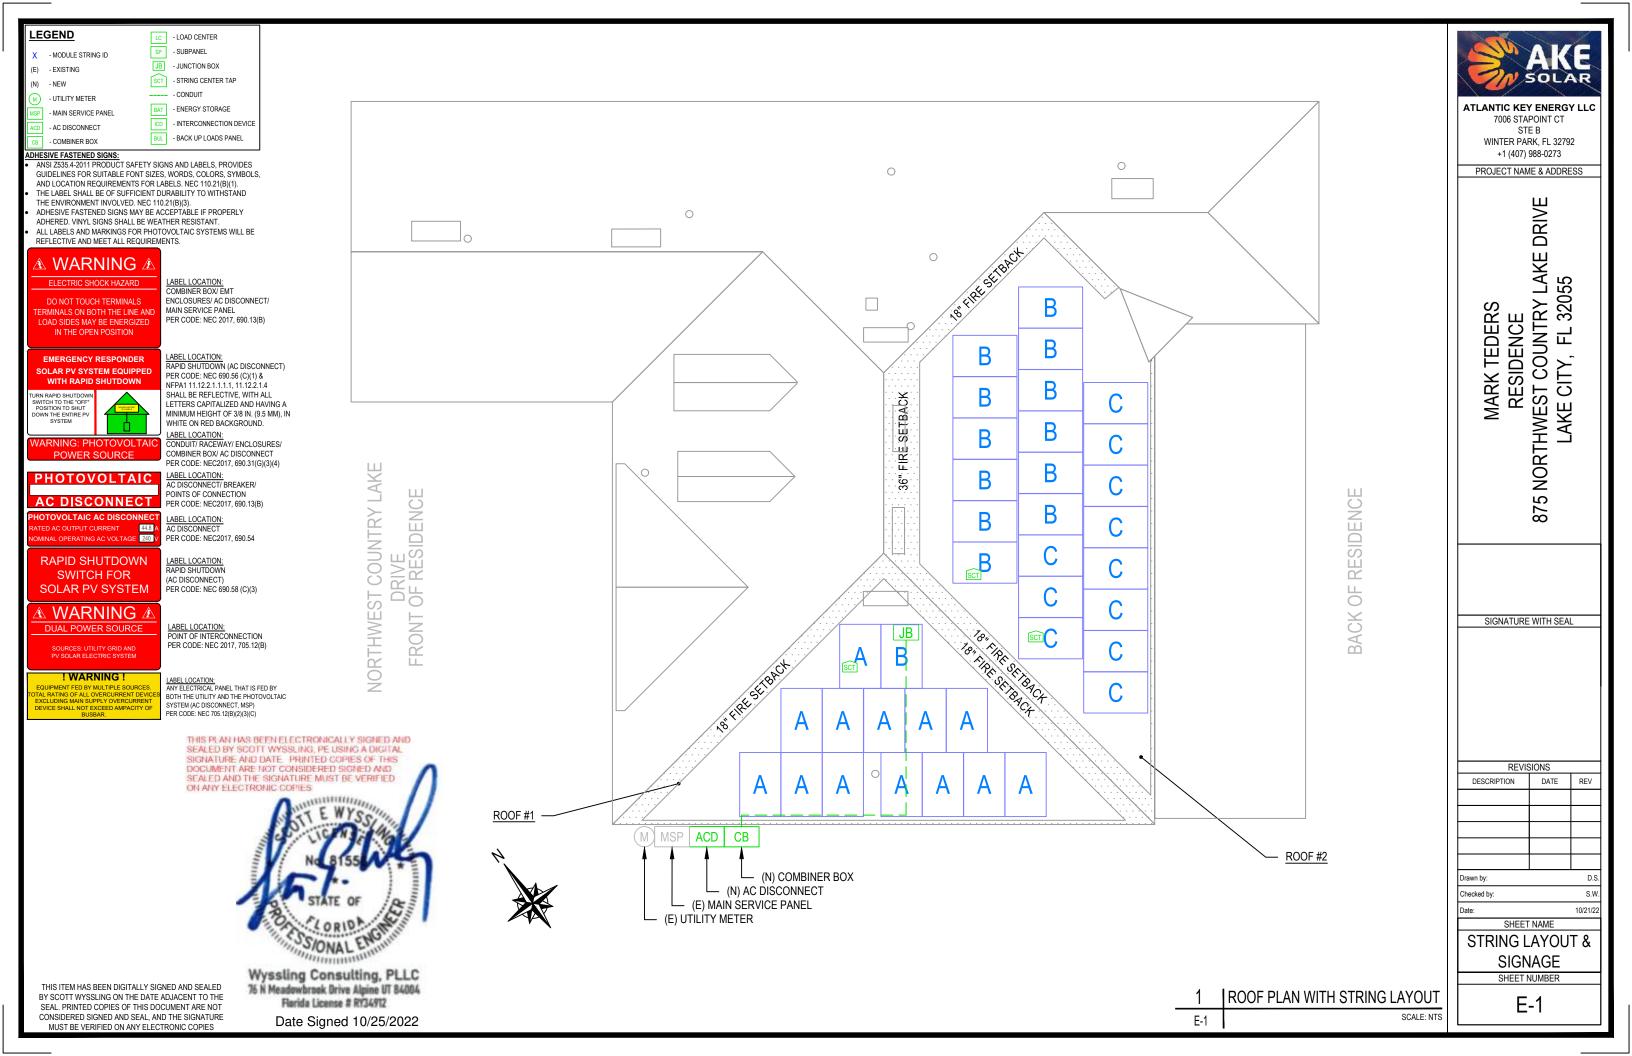

| ID | INITIAL CONDUCTOR | FINAL CONDUCTOR | MI | N. CONDUCTOR SIZE (AWG) | MIN. DIA CONDUIT SIZE | # OF PARALLEL | CURRENT-CARRYING CONDUCTORS IN | OCPD | | MIN. EGC SIZE (AWG) | TEMP. | | CONDUIT FILL | CONT. CURRENT (A) | MAX. CURRENT | BASE AMP. | DERATED AMP. | TERM. AMP. RATING | LENGTH (FT) | VOLTAGE DROP | |
|----------------|---|---|-------------------|----------------------------|--------------------------|----------------------------|-----------------------------------|------------------------------|------------|-------------------------------|-----------------|-----------------|--------------------|----------------------|-----------------------------|----------------------|---|---|--|-------------------------------------|---|
| | LOCATION | LOCATION | 40 | Q CABLE | (IN.) | CIRCUITS | CONDUIT | (A) | ^ | · , | FAC | | FACTOR | | (A) | (A) | (A) | (A) | 54.00 | (%) | AKE |
| 2 | STRING A STRING B | JUNCTION BOX JUNCTION BOX | 12 12 | Q CABLE Q CABLE | N/A N/A | 1 | 2 | N/A N/A | 6 | BARE COPPER BARE COPPER | 0.76 | 55°C 55°C | N/A N/A | 15.73 15.73 | 19.66 19.66 | 30 | N/A N/A | N/A N/A | 54.00 54.00 | 0.57 0.57 | SOLAR |
| 3 | STRING C | JUNCTION BOX | 12 | Q CABLE | N/A | 1 | 2 | N/A | 6 | BARE COPPER | 0.76 | 55°C | N/A | 13.31 | 16.64 | 30 | N/A | N/A | 59.00 | 0.53 | ATLANTIC KEY ENERGY LLC 7006 STAPOINT CT |
| 4 | JUNCTION BOX | IQ COMBINER | 10 | THWN-2 COPPER | 0.75 LTNM | 3 | 6 | 20 | 10 | THWN-2 COPPER | 0.76 | 55°C | 0.8 | 15.73 | 19.66 | 40 | 24.3 | 35 | 40.00 | 0.65 | STE B WINTER PARK, FL 32792 |
| 5 | IQ COMBINER | AC DISCONNECT | 6 | THWN-2 COPPER | 0.75 LTNM | 1 | 3 | 60 | 10 | THWN-2 COPPER | 0.96 | 33°C | 1 | 44.77 | 55.96 | 75 | 72.0 | 65 | 5.00 | 0.09 | +1 (407) 988-0273 PROJECT NAME & ADDRESS |
| 6 | AC DISCONNECT | MSP | 6 | THWN-2 COPPER | 0.75 LTNM | 1 | 3 | N/A | 8 | THWN-2 COPPER | 0.96 | 33°C | 1 | 44.77 | 55.96 | 75 | 72.0 | 65 | 5.00 | 0.09 | |
| | - 13 Q.PEAK DUO BLK M | N) STRING A L-G10+ 400W MODULES 72-2-US MICROINVERTEI N) STRING B L-G10+ 400W MODULES 72-2-US MICROINVERTEI N) STRING C | Z Z B RS | | 2 3 | | 4 | 20A/2P | 10A | NVOY NZP OR 5A/ZP | | | | TO UT | (E) BI-DIRE UTILITY ME | CTIONAL | EAKER | TT WYSSLING, PODATE PRINTED NOT CONSIDER E SIGNATURE MONIC COPIES No ST. Vyssling Co. N Meadowbrook Rarida Lice | DE USING A DIGI D COPIES OF THE EEP SIGNED AND UST BE VERIFIE BYSS ATE OF ORID O | PLLC IT 84004 | MARK TEDERS RESIDENCE 875 NORTHWEST COUNTRY LAKE DRIVE LAKE CITY, FL 32055 |
| | | L-G10+ 400W MODULES 2 | Z I | TO MOUNTING STRUCTURE | 6A | JUNCTION BOX WG BARE | | 20A/2P 20A/2P (N) IQ C | 15 OMBINER | BOX (N) POWER PERFECT BOX | 11 12 N N G (N) | FUSED ACCONNECT | LI LI N G | (E) MAIN | OCOCIO OCOCIO SERVICE | OUND CODE CTOR | | U I I I I I I I I I I I I I I I I I I I | (E (N | .EGEND E) - EXISTING I) - NEW | REVISIONS DESCRIPTION DATE REV Drawn by: D.S. Checked by: S.W. Date: 10/21/22 SHEET NAME ELECTRICAL LINE |
| BY SE CO | IS ITEM HAS BEEN DIGITALLY SCOTT WYSSLING ON THE DA AL. PRINTED COPIES OF THIS NSIDERED SIGNED AND SEAL MUST BE VERIFIED ON ANY EL | TE ADJACENT TO THE DOCUMENT ARE NOT , AND THE SIGNATURE | | | | | 1 E-2 | ELECTF | RICAL LI | NE DIAGRAM SCALE: NTS | | | | | | Al C | ECORD LOW T MBIENT TEMP ONDUIT HEIGH ONDUCTOR TE | (HIGH TEMP 2 IT | , | -6°C 33°C 1.0" 55°C | DIAGRAM & CALCS. SHEET NUMBER E-2 |

MECHANICAL SPECIFICATION

| Format | 74.0 in × 41.1 in × 1.26 in (including frame) |
|--------------|---|
| | (1879mm x 1945mm x 32mm) |
| Weight | 48.5 bs (22.0 kg) |
| Front Cover | 0.13 in (\$.2mm) thermally pre-stressed glass with anti-reflection technology |
| Back Cover | Composite film |
| Frame | Black anodized aluminum |
| Cell | 8 x 22 monocrystalline Q.ANTUM solar half cells |
| Junction Box | 2.09-3.98 in × 1.26-2.36 in × 0.59-0.71 in |
| | (53-101mm × 32-60 mm × 15-18mm), IP67, with bypass diodes |
| Cable | 4mm² Solar cable; (+) ≥49.2 in (1250 mm), (-) ≥49.2 in (1250 mm) |
| Connector | Staubli MC4; IP68 |

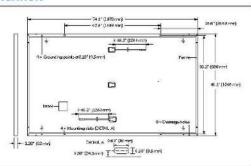


ELECTRICAL CHARACTERISTICS

| PO | WER CLASS | | | 385 | 390 | 395 | 400 | 405 |
|--------|------------------------------------|------------------|---------------|-----------------|----------|-------|-------|-------|
| CALL | IMUM PERFORMANCE AT STANDA | RD TEST CONDITIO | NS, STC+ (PO) | WER TOLERANCE + | 5 W/-0W) | | | |
| | Powerat MPP* | P _{MPP} | [W] | 385 | 390 | 395 | 400 | 405 |
| SHO | Short Circuit Current ⁶ | l ₅₀ | [A] | 11,04 | 1,1,07 | 11.10 | 11.14 | 11.17 |
| III. | Open Circuit Voltage ^a | Vos | [V] | 45.19 | 45.23 | 45.27 | 45.30 | 45,34 |
| Minih | Current at MPP | MPP | [A] | 10.59 | 10.65 | 10.71 | 10.77 | 10.83 |
| 2 | Voltage at MPP | VMPP | [V] | 36.36 | 36.62 | 36.88 | 37.13 | 37.39 |
| | Efficiency ¹ | η | [%] | ≥19.6 | ≥19.9 | ≥20.1 | ≥20.4 | ≥20.6 |
| (VIII) | IIMUM PERFORMANCE AT NORMA | L OPERATING CONF | DITIONS, NMC |)T² | | | | |
| | Power at MPP | PMP | [W] | 288.8 | 292,6 | 296.3 | 300.1 | 303.8 |
| E | Short Circuit Current | lsc | [A] | 8,90 | 8.92 | 8,95 | 8,97 | 9.00 |
| ile) | Open Circuit Voltage | Vos | [V] | 42,62 | 42.65 | 42.69 | 42,72 | 42.76 |
| Σ | Current at MFP | upp | [A] | 8.35 | 8.41 | 8,46 | 8.51 | 8,57 |
| | Voltage at MPP | V _{MPP} | [V]: | 34,59 | 34.81 | 35.03 | 35.25 | 35.46 |


 $\label{eq:proposed_$ Q CELLS PERFORMANCE WARRANTY

PERFORMANCE AT LOW IRRADIANCE

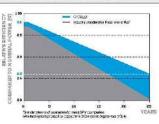

Atleast98% of nominal power during first year. Thereafter max. 0.5% degradation per year. Atleast 98.5% of nominal power up to 10 years. At least 86% of nominal power up to 25 years.

 All data within measurement tolerances. Full warrantes in accordance with the warranty terms of the Q CELLS sales organisation of your respective ocuntry.



Typical module performance under low irradiance conditions in comparison to STC conditions (25°C, 1000 W/m²)

| TEMPERATURE COEFFICIENTS | | | | | | | | | |
|--|---|-------|-------|--|------|-------|------------------|--|--|
| Temperature Coefficient of I _{sc} | q | [%/K] | +0.04 | Temperature Coefficient of V _{cc} | β | [%/K] | -0.27 | | |
| Temperature Coefficient of P _{MP} | Y | [%/K] | -0.34 | Nominal Module Operating Temperature | NMOT | [°F] | 109±5.4 (43±3°C) | | |

PROPERTIES FOR SYSTEM DESIGN

| Maximum System Voltage V | TVI | 1000 (EC)/1000 (UL) | PV module classification | Class II |
|--------------------------------|------------------------|-----------------------------|------------------------------------|-----------------------|
| Maximum Series Fuse Rating | [A DC] | | Fire Rating based on ANSI/UL 61730 | TYPE 2 |
| Max. Design Load, Push / Pull* | [lbs/ft²] | 75 (3600 Pa) / 55 (2660 Pa) | Permitted Module Temperature | -40°F up to +185°F |
| Max. Test Load, Push/Pulls | [lbs/ft ²] | 113 (5400Pa) / 84 (4000Pa) | on Continuous Duty | (−40 °C up to +85 °C) |

QUALIFICATIONS AND CERTIFICATES

PACKAGING INFORMATION

UL 61730, CE-compliant, Quality Controlled PV - TUV Rheinland, EC 612152 C16, EC 61730-2016, U.S. Patert No. 9,883,715 (solar cells), QOPV Certification engoing

³ See Installation Manual







| | | | | (P) | 0-0 | 40 HO | |
|------------|---------|---------|--------|---------|---------|---------|---------|
| Horizontal | 76.41n | 43.3 in | 48.01n | 1656lbs | 24 | 24 | 32 |
| packaging | 1940 mm | 1100mm | 1220mm | 751kg | pallets | pallets | modules |

Note: Installation instructions must be followed. See the installation and operating manual or contact our technical service department for further information on approved installation and use of this product.

Hanwha Q CELLS America Inc.

400 Spectrum Center Crive, Suite 1400, Invine, CA 92618, USA | TEL +1, 349 748 59 96 | EMAIL Inquiry@usq-cells.com | WEB www.q-cells.us

IO8 and IO8+ Microinverters

| INPUT BATA (BC) | | 108-60-2-02 | 108PLUS-72-2-US | | | | | |
|--|-----|--|---|--|--|--|--|--|
| Commonly used module pairings* | W | 235 - 350 | 235 - 440 | | | | | |
| Module compatibility | | 60-cell/120 half-cell | 60-cell/120 half-cell and 72-cell/144 half-cell | | | | | |
| MPPT voltage range | V | 27 - 37 | 29 - 45 | | | | | |
| Operating range | v | 25 - 48 | 25 - 58 | | | | | |
| Min/max start voltage | v | 30 / 48 | 30 / 58 | | | | | |
| Max input DC voltage | v | 50 | 60 | | | | | |
| Max DO current® [module lsc] | А | | 15 | | | | | |
| Overvoltage class DC port | | | 1 | | | | | |
| DC port backfeed current | mA | | 0 | | | | | |
| PV array configuration | | IxI Ungrounded array; No additional DC side protection | on required; AC side protection requires max 20A per branch circuit | | | | | |
| OUTPUT DATA (AC) | | 108-60-2-05 | 108PLUS-72-2-US | | | | | |
| Peak output power | VA | 245 | 300 | | | | | |
| Max continuous output power | VA | 240 | 290 | | | | | |
| Nominal (L-L) voltage/range ³ | V | - 2 | 240 / 211 - 264 | | | | | |
| Max continuous output current | A | 10 | 1.21 | | | | | |
| Nominal frequency | Hz | | 60 | | | | | |
| Extended frequency range | Hz | | 50 - 68 | | | | | |
| Max units per 20 A (L-L) branch circu | it* | 16 | 13 | | | | | |
| Total harmonic distortion | | | <5% | | | | | |
| Overvoltage class AC port | | | ш | | | | | |
| AC port backfeed current | mA | | 30 | | | | | |
| Power factor setting | | | 1.0 | | | | | |
| Grid-tied power factor (adjustable) | | O.85 le | ading - 0.85 lagging | | | | | |
| Peak efficiency | % | 97.5 | 97.6 | | | | | |
| CEC weighted efficiency | % | 97 | 97 | | | | | |
| Night-time power consumption | mi¥ | | 60 | | | | | |
| HECHANICAL DATA | | | | | | | | |
| Ambient temperature range | | -40°C to + | 60°C (-40°F to+140°F) | | | | | |
| Relative humidity range | | 4% to | 100% (condensing) | | | | | |
| DC Connector type | | | MC4 | | | | | |
| Dimensions (HxWxD) | | 212 mm (8.3") x 175 mm (6.9") x 30.2 mm (1.2") | | | | | | |
| Weight | | 1.08 kg (2.38 lbs) | | | | | | |
| Cooling | | Natural convection - no fans | | | | | | |
| Approved for wet locations | | Yes | | | | | | |
| Acoustic noise at 1 m | | | <60 dBA | | | | | |
| Pollution degree | | | PD3 | | | | | |
| Enclosure | | Class II double-insulated, | corrosion resistant polymeric enclosure | | | | | |
| Environ. category / UV exposure ratin | na | NEM | A Type 6 / outdoor | | | | | |

CA Rule 21 (UL 1741-SA), UL 62109-1, UL1741/IEEE1547, FCC Part 15 Class B, ICES-0003 Class B, CAN/CSA-C22.2 NO. 107.1-01

This product is UL Listed as PV Rapid Shut Down Equipment and conforms with NEC 2014, NEC 2017, and NEC 2020 section 690.12 and C22.1-2018 Rule 64-218 Rapid Shutdown of PV Systems, for AC and DC concluctors, when installed according to

(1) No enforced DC/AC ratio. See the compatibility calculator at https://link.enphase.com/module-compatibility (2) Maximum continuous input DC current is 10.6A (3) Nominal voltage range can be extended beyond nominal if required by the utility. (4) Limits may vary. Refer to local requirements to define the number of microinverters per branch in your area.

manufacturer's instructions.

Certifications

IQ8SP-DS-0002-01-EN-US-2021-10-19



ATLANTIC KEY ENERGY LLC 7006 STAPOINT CT STE B WINTER PARK, FL 32792 +1 (407) 988-0273

PROJECT NAME & ADDRESS

MARK TEDERS RESIDENCE 875 NORTHWEST COUNTRY LAKE DRIVE LAKE CITY, FL 32055

SIGNATURE WITH SEAL

REVISIONS REV DESCRIPTION DATE

S.W. Checked by: 10/21/22

Drawn by:

SHEET NAME **EQUIPMENT**

SPECIFICATIONS SHEET NUMBER

E-3

Enphase IQ Combiner 4/4C

| MODEL NUMBER | |
|---|--|
| IQ Combiner 4 (X-IQ-AMT-240-4) | IQ Combiner 4 with Enphase IQ Gateway printed circuit board for integrated revenue grade PV production metering (ANS C12.20 +/-0.5%) and consumption monitoring (+/-2.5%). Includes a silver solar shield to match the IQ Battery system an IQ System Controller 2 and to deflect heat. |
| IQ Combiner 4C (X-IQ-AM1-240-4C) | IQ Combiner 4C with Enphase IQ Gateway printed circuit board for integrated revenue grade PV production metering (ANSI 012.20 +/- 0.5%) and consumption monitoring (+/- 2.5%). Includes Enphase Mobile Connect cellular modern (CELLMODEM-M1-06-SP-05), a plug-and-play inclustrial-grade cell modern for systems up to 60 microinverters. (Available in the US, Canada, Mexico, Puerto Rico, and the US Virgin Islands, where there is a dequate cellular service in the installation area.) Includes a alliver solar shield to match the IQ Battery and IQ System Controller and to deflect heat |
| ACCESSORIES AND REPLACEMENT PARTS | (not included, order separately) |
| Ensemble Communications Kit COMMS-CELLMODEM-M1-06 CELLMODEM-M1-06-SP-05 CELLMODEM-M1-06-AT-05 | Includes COMMS-KIT-01 and CELLMODEM-M1-06-SP-05 with 5-year Sprint data plan for Ensemble sites 46 based LTE-M1 cellular modem with 5-year Sprint data plan 46 based LTE-M1 cellular modem with 5-year AT&T data plan |
| Circuit Breakers BRK-10A-2-240V BRK-15A-2-240V BRK-20A-2P-240V BRK-15A-2P-240V-B BRK-20A-2P-240V-B | Supports Eaton BR210, BR215, BR220, BR230, BR240, BR250, and BR260 circuit breakers. Circuit breaker, 2 pole, 10A, Eaton BR210 Circuit breaker, 2 pole, 15A, Eaton BR215 Circuit breaker, 2 pole, 20A, Eaton BR220 Circuit breaker, 2 pole, 15A, Eaton BR215 with hold down kit support Circuit breaker, 2 pole, 20A, Eaton BR2208 with hold down kit support |
| EPLG-01 | Power line carrier (communication bridge pair), quantity - one pair |
| X A-SOLARSHIELD-ES | Replacement solar shield for IQ Combiner 4/4C |
| XA-PLUG-120-3 | Accessory receptable for Power Line Carrier in IQ Combiner 4/4C (required for EPLC-01) |
| XA-ENV-PCBA-3 | Replacement IQ Gateway printed circuit board (PCB) for Combiner 4/4C |
| X-IQ-NA-HD-125A | Hold down kit for Eaton circuit breaker with screws. |
| ELECTRICAL SPECIFICATIONS | |
| Rating | Continuous duty |
| System voltage | 120/240 VAC, 60 Hz |
| Eaton BR series busbar rating | 125 A |
| Max. continuous current rating | 65A |
| Max. continuous current rating (input from PV/storage) | 64 A |
| Max. fuse/circuit rating (output) | 90 A |
| Branch circuits (solar and/or storage) | Up to four 2-pole Eaton BR series Distributed Generation (DG) breakers only (not included) |
| Max. total branch circuit breaker rating (input) | 80A of distributed generation / 95A with IQ Gateway breaker included |
| Production metering CT | 200 A solid core pre-installed and wired to IQ Gateway |
| Consumption monitoring CT (CT-200-SPLIT) | A pair of 200 A split core current transformers |
| MECHANICAL DATA | |
| Dimensions (WxHxD) | 37.5 x 49.5 x 16.8 cm (14.75" x 19.5" x 6.63"). Height is 21.06" (53.5 cm) with mounting brackets. |
| Weight | 7.5 kg (16.5 lbs) |
| Ambient temperature range | -40° C to +46° C (-40° to 115° F) |
| Cooling | Natural convection, plus heat shield |
| Enclosure environmental rating | Outdoor, NRTL-certified, NEMA type 3R, polycarbonate construction |
| Wire sizes | 20 A to 50 A breaker inputs: 14 to 4 AWG copper conductors 60 A breaker branch input: 4 to 1/0 AWG copper conductors Main lug combined output: 10 to 2/0 AWG copper conductors Neutral and ground: 14 to 1/0 copper conductors Always follow local code requirements for conductor sizing. |
| Altitude | To 2000 meters (6,560 feet) |
| INTERNET CONNECTION OPTIONS | |
| Integrated Wi-Fi | 802.11b/g/n |
| Cellular | CELLMODEM-M1-06-SP-05, CELLMODEM-M1-06-AT-05 (4G based LTE-M1 cellular modern). Note that an Enphase Mobile Connect cellular modern is required for all Ensemble installations. |
| Ethernet | Optional, 802.3; Cat5E (or Cat 6) UTP Ethernet cable (not included) |
| COMPLIANCE | |
| Compliance, IQ Combiner | UL 1741, OAN/CSA C22.2 No. 107.1, 47 CFR, Part 15, Class B, ICES 003 Production metering: ANSI C12.20 accuracy class 0.5 (PV production) Consumption metering: accuracy class 2.5 |
| Compliance, IQ Gateway | UL 60601-1/CANCSA 22.2 No. 61010-1 |

To learn more about Enphase offerings, visit enphase.com
© 2021 Enphase Energy, All rights reserved. Enphase, the Enphase logo, IQ Combiner 4/4C, and other names are trademarks of Enphase Energy, Inc. Data subject to change. 10-21-2021



ATLANTIC KEY ENERGY LLC
7006 STAPOINT CT
STE B
WINTER PARK, FL 32792
+1 (407) 988-0273

PROJECT NAME & ADDRESS

MARK TEDERS RESIDENCE 875 NORTHWEST COUNTRY LAKE DRIVE LAKE CITY, FL 32055

SIGNATURE WITH SEAL

REVISIONS DESCRIPTION DATE REV

Checked by:

10/21/22

⊖ ENPHASE.

SHEET NAME **EQUIPMENT**

SPECIFICATIONS SHEET NUMBER