

EQUIPOTENTIAL BONDING GRID:

ALL METAL PARTS SPECIFIED IN 680.26(B) MUST BE BONDED TO AN EQUIPOTENTIAL BONDING GRID WITH A SOLID COPPER CONDUCTOR NOT SMALL THAN 8 AWG. THE TERMINATION OF THE BONDING CONDUCTOR MUST BE MADE BY EXOTHERMIC WELDING, LISTED PRESSURE CONNECTORS, OR LISTED CLAMPS THAT ARE LABELED AS SUITABLE FOR THE PURPOSE. THE EQUIPOTENTIAL BONDING GRID MUST EXTEND UNDER PAVED WALKING SURFACES FOR 3 FEET HORIZONTALLY FROM THE WATER (680.26(C)).

THE EQUIPOTENTIAL BONDING GRID MUST BE FORMED FROM EITHER OR BOTH OF:

THE STRUCTURAL REINFORCING STEEL OF A CONCRETE PERMANENTLY INSTALLED POOL, OUTDOOR SPA, OR OUTDOOR HOT TUB, TIED TOGETHER BY THE USUAL STEEL TIE WIRES.

THE METAL WALLS OF A PERMANENTLY INSTALLED POOL, OUTDOOR SPA, OR OUTDOOR HOT TUB

THE EQUIPOTENTIAL BONDING GRID CAN BE CONSTRUCTED WITH 8 AWG BARE SOLID COPPER CONDUCTORS BONDED TO EACH OTHER AT ALL POINTS OF CROSSING BY EXOTHERMIC WELDING, LISTED PRESSURE CONNECTORS OF THE SET SCREW OR COMPRESSION TYPE, LISTED CLAMPS, OR OTHER LISTED FITTINGS (250.8).


THE EQUIPOTENTIAL BONDING GRID MUST COVER THE CONTOUR OF THE PERMANENTLY INSTALLED POOL, OUTDOOR SPA OR HOT TUB AND DECK EXTENDING 3 FEET HORIZONTALLY FROM THE WATER. THE EQUIPOTENTIAL BONDING GRID MUST BE ARRANGED IN A 1-FOOT BY 1-FOOT NETWORK OF 8 AWG CONDUCTORS, WITH A TOLERANCE OF 4 INCHES.

EXCEPTION: THE EQUIPOTENTIAL BONDING GRID SHALL NOT BE REQUIRED TO BE INSTALLED UNDER THE BOTTOM OR VERTICALLY ALONG THE WALLS OF VINYL LINED POLYMER WALL, FIBERGLASS COMPOSITE, OR OTHER POOLS CONSTRUCTED OF NON-CONDUCTIVE MATERIALS.

ANY METAL PARTS OF THE POOL, INCLUDING METAL STRUCTURAL SUPPORTS, SHALL BE BONDED IN ACCORDANCE WITH 680.26(B). POURED CONCRETE, PNEUMATICALLY-APPLIED CONCRETE, AND CONCRETE BLOCK SHALL BE CONSIDERED CONDUCTIVE MATERIAL


GENERAL NOTES:

- 1) Per UL listing, pool motors require GFCI protection
- 2) FSPA requires the motor controller to be capable of 2 speeds, a time clock will not satisfy this unless it has 2 trip settings.
- 3) If heater installed (other than solar), it must comply with FBC-EC403.9.1 & have a cover per 403.9.3 (this applies to mechanical (not solar) heaters---cover required)
- 4) Outdoor swimming pools shall be provided with a barrier complying with Sections R4501.17.1.1 through R4501.17.1.14.
- 5) NEC 680.26(C) requires a conductive metal part of 9 sq. in. in direct contact with the pool water.
- 6) R4501.17.1.9 All doors and windows providing direct access from the home to the pool shall be equipped with an exit alarm complying with UL 2017 that has a minimum sound pressure rating of 85 dB at 10 feet.

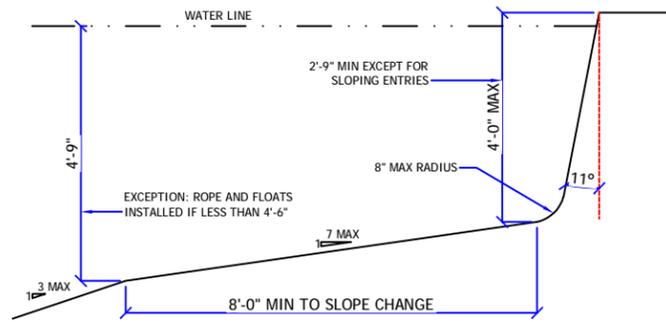


FLOOR SLOPE DETAIL NTS

STEPS: MIN. TREAD 10" x 12", 7" MIN RISER, 12" MAX RISER. INTERMEDIATE TREADS AND RISERS TO BE UNIFORM.

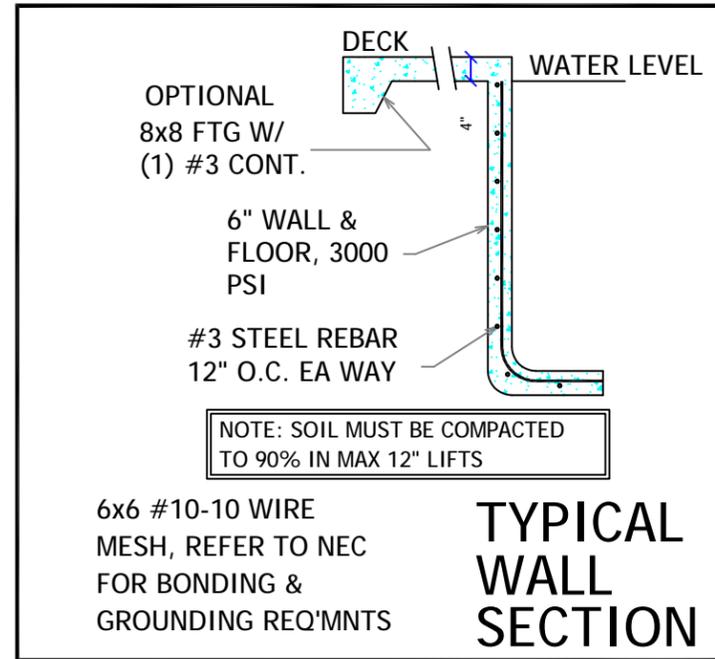

NOTE: IF ANY PART OF THE POOL ENCROACHES UPON THE ANGLE OF REPOSE, PLACE STEEL @ 6" o.c. EA WAY IN AREAS OF QUESTION

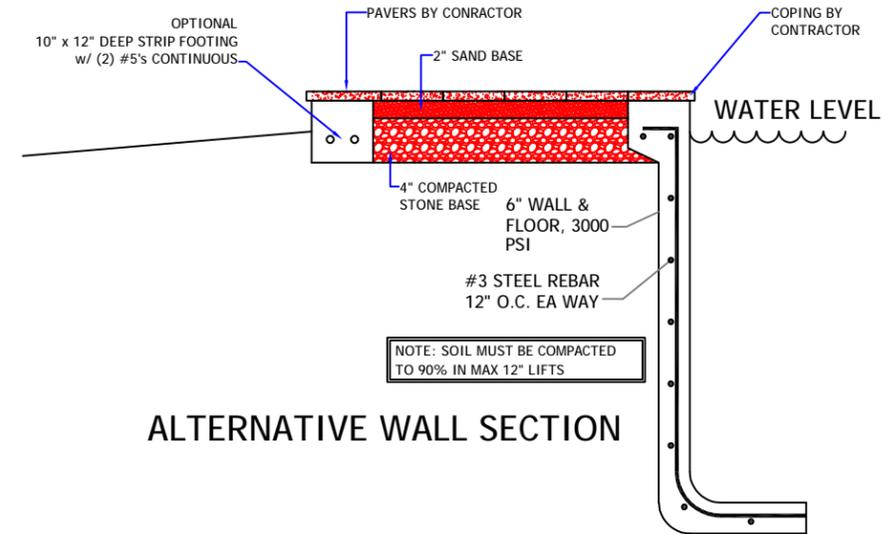

ALTERNATIVE WALL SECTION


- ENGINEERING NOTES:
1. ALL WORK IS TO COMPLY WITH ALL APPLICABLE CODES & ORDINANCES.
 2. CONSTRUCTED OF 3000 PSI CONCRETE OR EQUAL WITH #3 REBAR 12" O.C. EACH WAY, TIED AT EVERY OTHER INTERSECTION. MIN COVER FOR REBAR IS 2.5" MIN OVERLAP IS 18".
 3. N/A

4. ASSUMED SOIL BEARING = 2 KSF
5. CIRCULATION SYSTEMS, COMPONENTS, & EQUIPMENT SHALL COMPLY W/ NSF 50.
6. INSTALL CONTROL JOINTS @ 20'-0" ON CENTER IN POOL DECKING.
7. PLANS TO CONFORM TO NEC 2020
8. 2023 FBC RESIDENTIAL 8th EDITION APSP13
9. CONCRETE STAIRS ARE 12" TREAD WIDTH AND 10" MAXIMUM HEIGHT
10. ALL CONSTRUCTION SHALL COMPLY WITH ANSI 5-03, 2020 NEC ARTICLE 680, & ANSI-NSPI 3-99 IN-GROUND SPA CONSTR.

*11. ENGINEERS DESIGN IS FOR STRUCTURAL ONLY. DESIGN OF PIPING/EQUIPMENT ETC.

BY POOL CONTRACTOR

- FENCE REQUIREMENTS:
1. MINIMUM 48" HEIGHT
 2. 2" MAX VERTICAL CLEARANCE BETWEEN GRADE & BARRIER BOTTOM.
 3. MAX OPENING SHALL NOT ALLOW PASSAGE OF 4" SPHERE.
 4. FENCE POSTS WILL BE LOCATED ON POOL-SIDE OF FENCE.
 5. GATE WILL BE SELF-LOCKING WITH APPROVED LOCKING DEVICE.

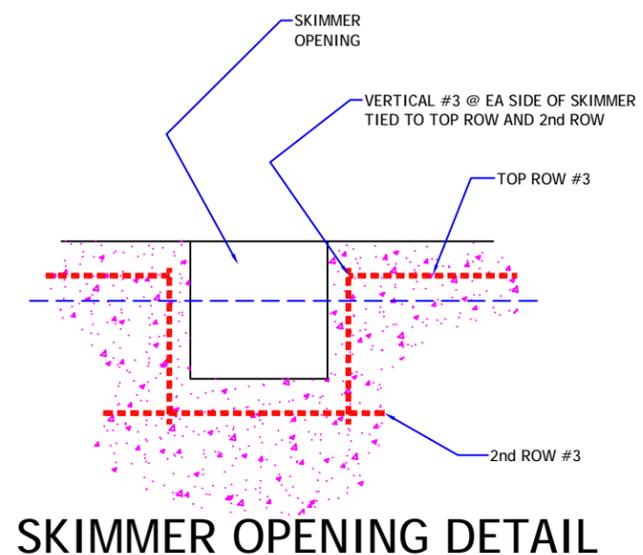

SKIMMER OPENING DETAIL

Riddle Consulting Engineers, Inc.

structural civil mechanical

Paul D. Riddle, P.E.
Senior Engineer
COA: 00004759

ADDRESS 1720 SE CTY HWY 484
BELLEVUE, FL 34420
PHONE (352) 245-7041
FAX (352) 245-5458
WEB: WWW.RIDDLEENGINEERING.COM

ENGINEER'S SEAL

PAUL D. RIDDLE, P.E.
P.E. 36989



THIS ITEM HAS BEEN DIGITALLY SIGNED AND SEALED BY PAUL D. RIDDLE, PE ON THE DATE ADJACENT TO THE SEAL. PRINTED COPIES OF THIS DOCUMENT ARE NOT CONSIDERED SIGNED AND SEALED AND THE SIGNATURE MUST BE VERIFIED ON ANY ELECTRONIC COPIES.

JOB No.: 2250000

DATE Dec. 4, 25

PROJECT DATA

A CUSTOM POOL DESIGN FOR MOSES RESIDENCE

Page:


1 of 4

3/16" = 1'-0" SCALE



Paul D. Riddle, P.E.
Senior Engineer
COA: 00004759

ADDRESS 1720 SE CTY HWY 484
BELLEVIEW, FL 34420
PHONE (352) 245-7041
FAX (352) 245-5458
WEB: WWW.RIDDLEENGINEERING.COM

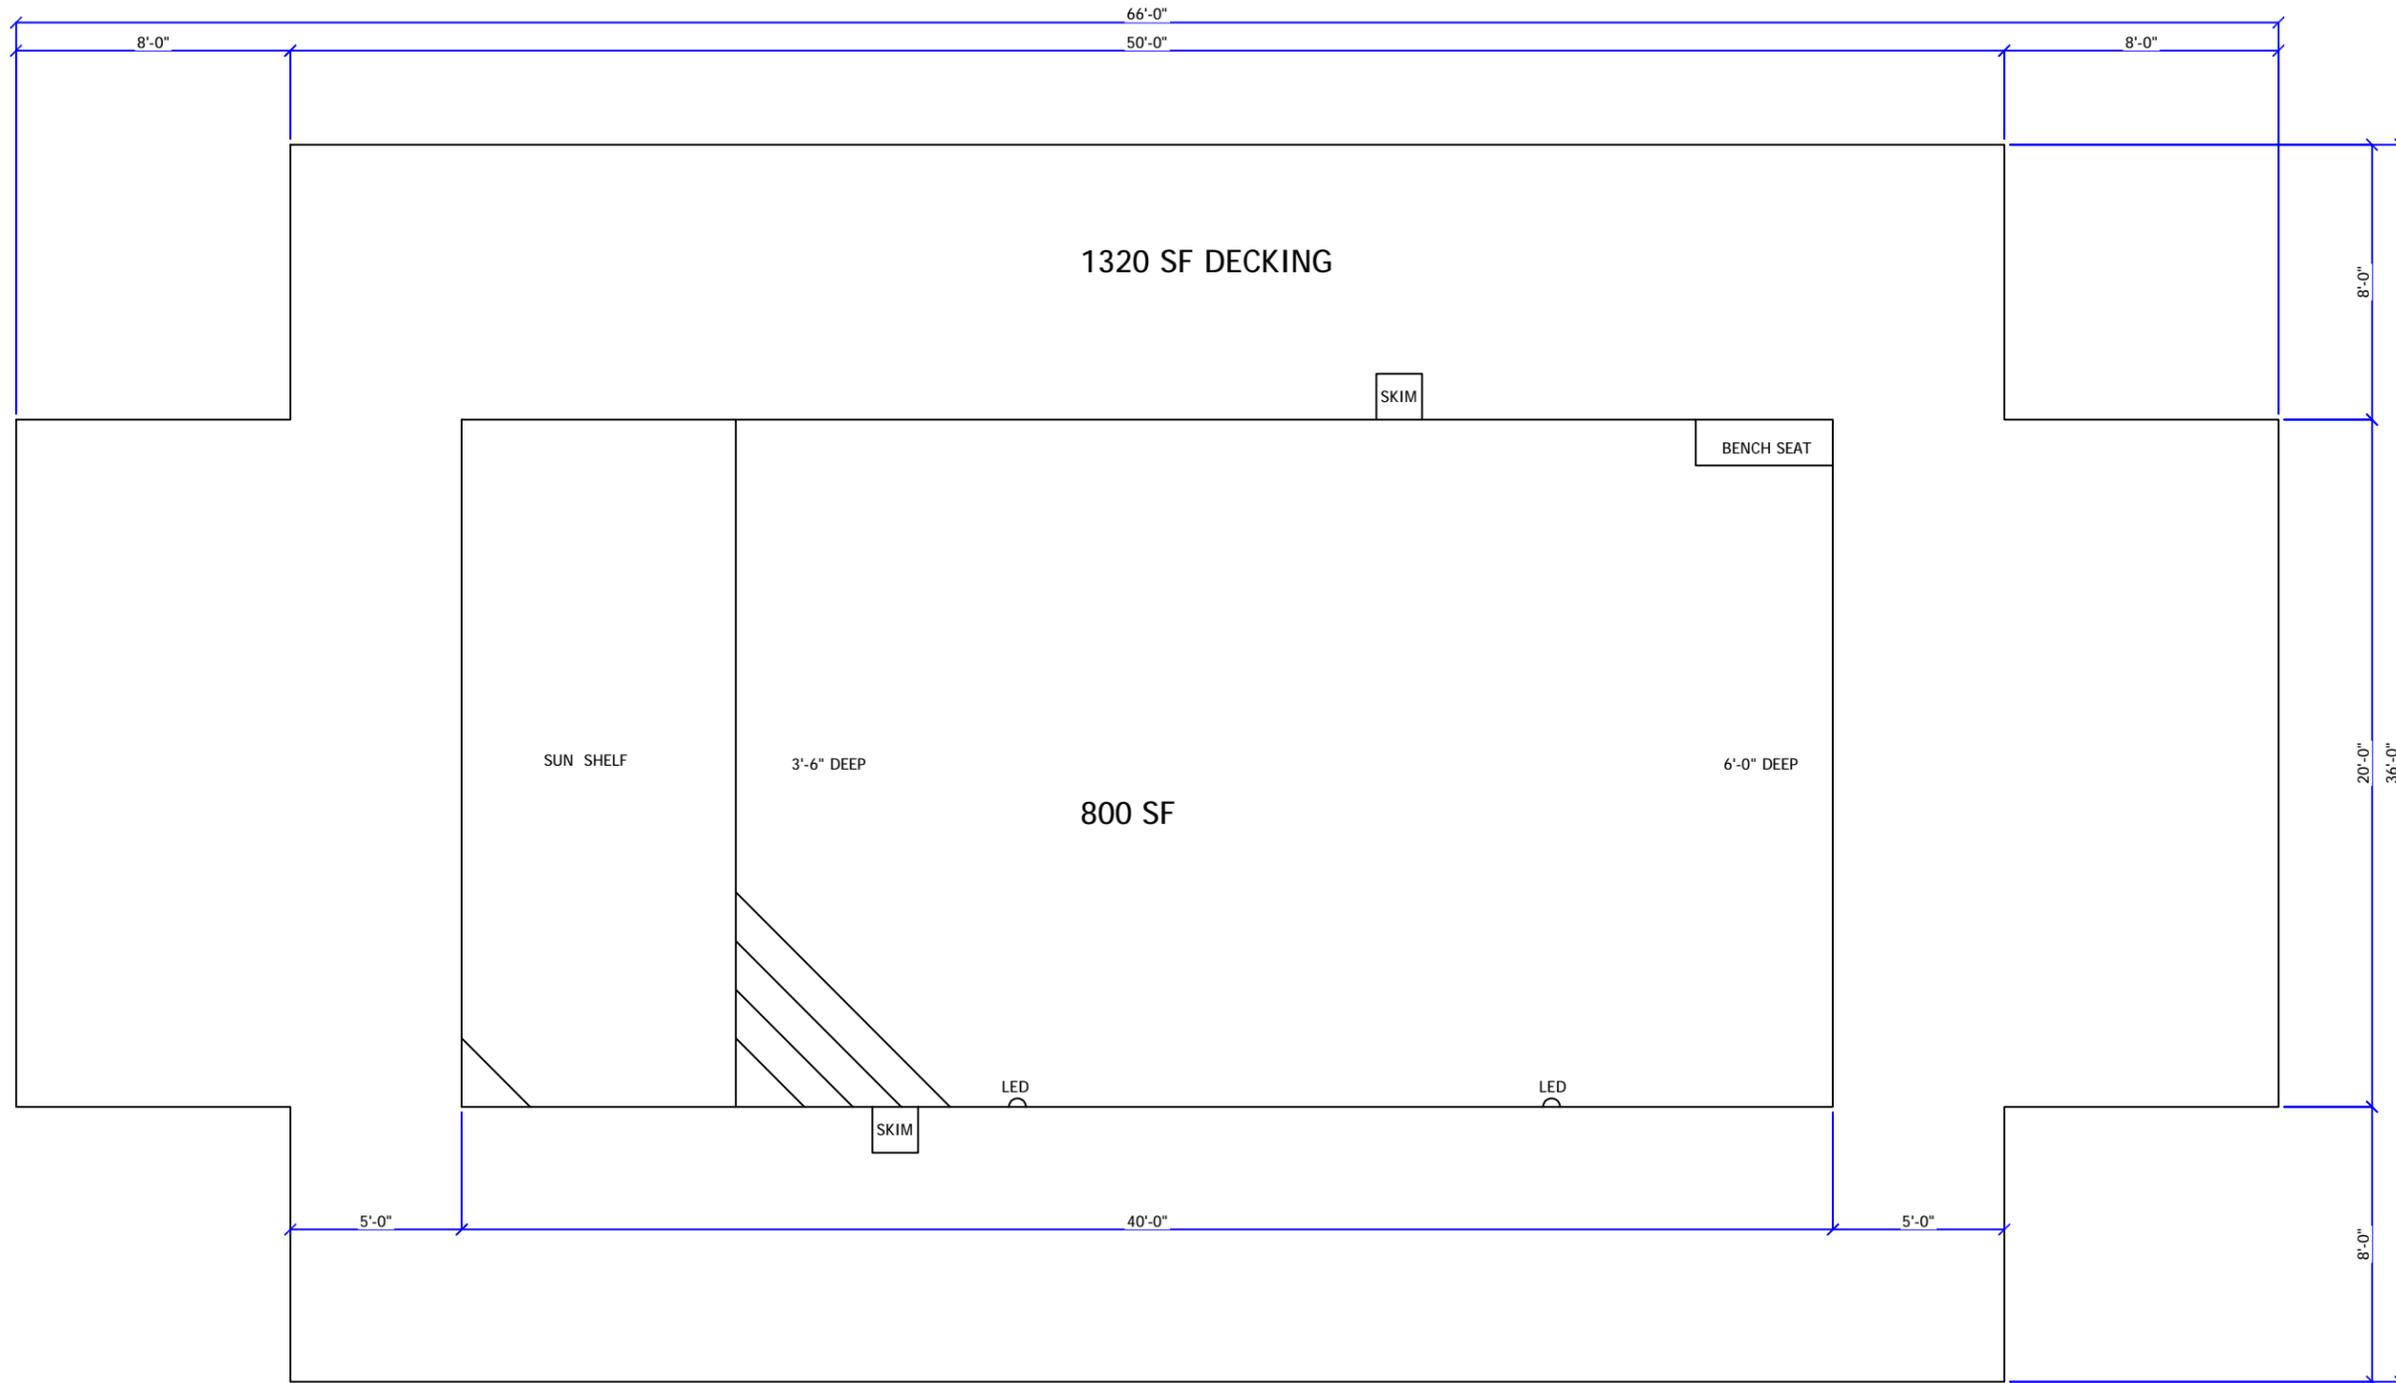

ENGINEER'S SEAL

PAUL D. RIDDLE, P.E.
P.E. 36989



THIS ITEM HAS BEEN DIGITALLY
SIGNED AND SEALED BY PAUL D.
RIDDLE, PE ON THE DATE ADJACENT TO
THE SEAL. PRINTED COPIES OF THIS
DOCUMENT ARE NOT CONSIDERED
SIGNED AND SEALED AND THE
SIGNATURE MUST BE VERIFIED ON ANY
ELECTRONIC COPIES.


JOB No.:

DATE Dec. 4, 25


PROJECT DATA

A CUSTOM POOL
DESIGN FOR
**MOSES
RESIDENCE**

PIPING KEY

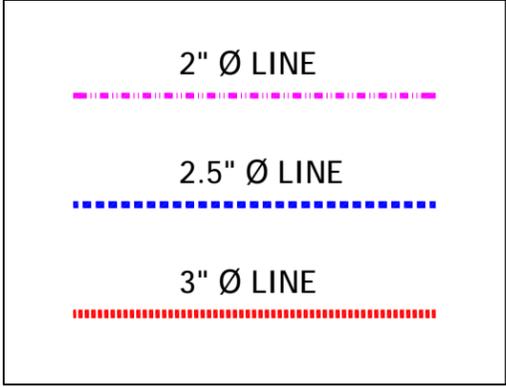

POOL EQUIPMENT

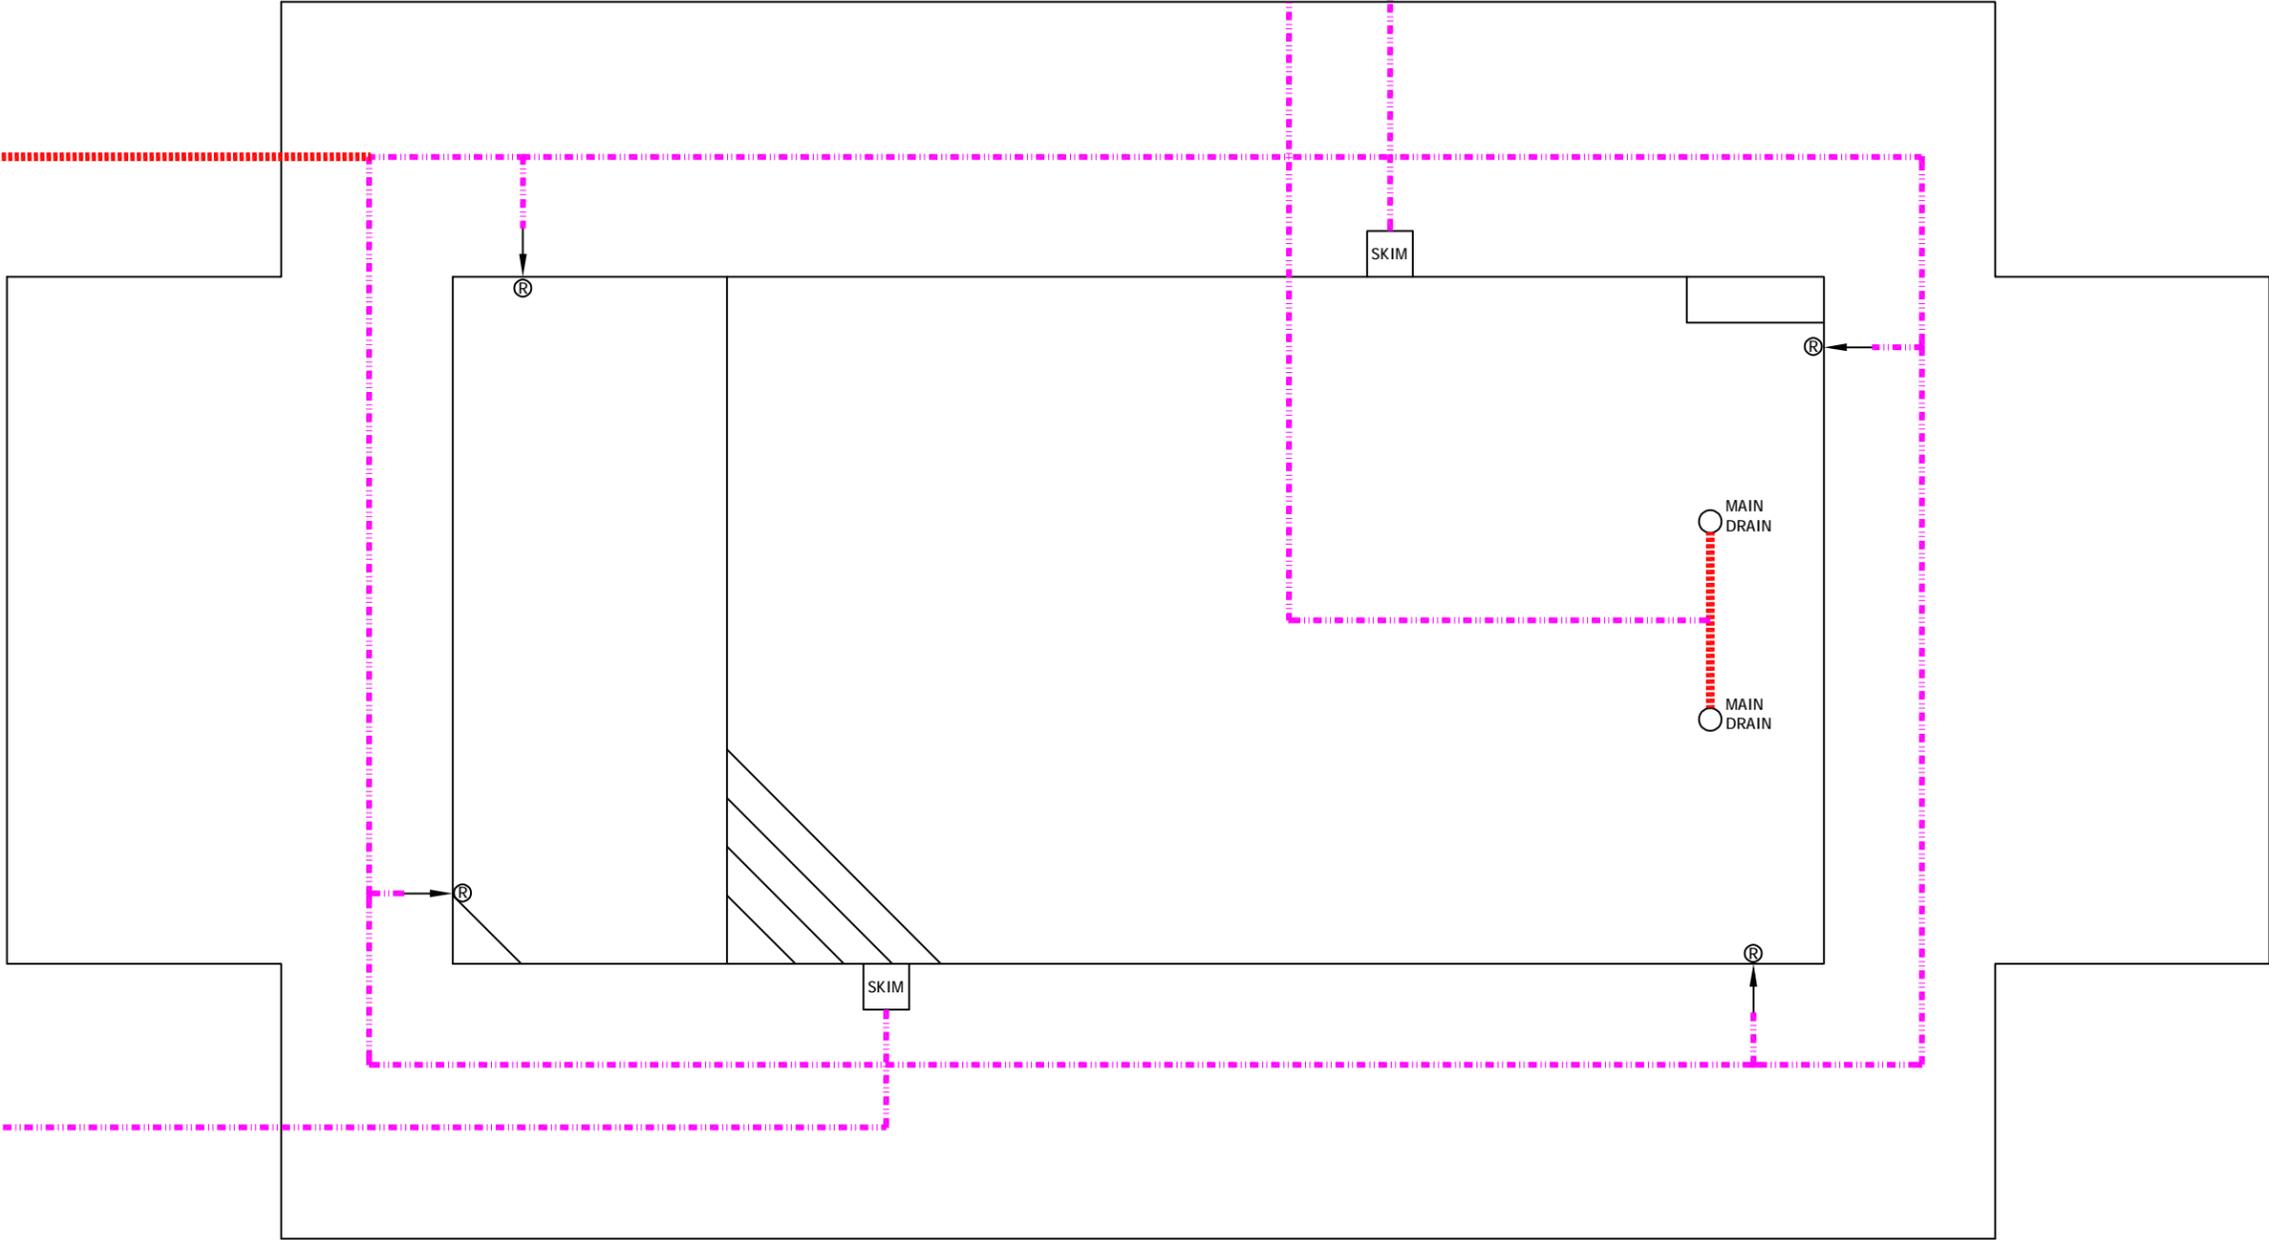

Riddle Consulting Engineers, Inc.

structural
civil
mechanical

Paul D. Riddle, P.E.
Senior Engineer
COA: 00004759

ADDRESS 1720 SE CTY HWY 484
BELLEVIEW, FL 34420
PHONE (352) 245-7041
FAX (352) 245-5458
WEB: WWW.RIDDLEENGINEERING.COM

ENGINEER'S SEAL

PAUL D. RIDDLE, P.E.
P.E. 36989



THIS ITEM HAS BEEN DIGITALLY SIGNED AND SEALED BY PAUL D. RIDDLE, PE ON THE DATE ADJACENT TO THE SEAL. PRINTED COPIES OF THIS DOCUMENT ARE NOT CONSIDERED SIGNED AND SEALED AND THE SIGNATURE MUST BE VERIFIED ON ANY ELECTRONIC COPIES.

JOB No.:

DATE Dec. 4, 25

PROJECT DATA

A CUSTOM POOL
DESIGN FOR
**MOSES
RESIDENCE**


Page:

3 of 4

3/16" = 1'-0" SCALE

ENGINEER'S SEAL

PAUL D. RIDDLE, P.E.
P.E. 36989

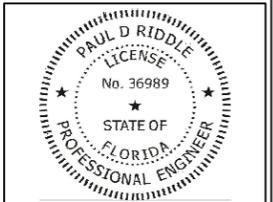

THIS ITEM HAS BEEN DIGITALLY SIGNED AND SEALED BY PAUL D. RIDDLE, PE ON THE DATE ADJACENT TO THE SEAL. PRINTED COPIES OF THIS DOCUMENT ARE NOT CONSIDERED SIGNED AND SEALED AND THE SIGNATURE MUST BE VERIFIED ON ANY ELECTRONIC COPIES.

JOB No.:
DATE Dec. 4, 25

PROJECT DATA

A CUSTOM POOL
DESIGN FOR
**MOSES
RESIDENCE**

NORTH FLORIDA POOLS

12/4/2025

MINIMUM FLOW REQ'D = 70.64 GPM
POOL VOLUME : SURFACE AREA X AVG DEPTH X 7.48 GAL / CF
VOL = 800 SF X 4.25 FT DEEP = 25432 Gallons
TURNOVER TIME: No. Hours X 60 min / hour
6 hours x 60 = 360 minutes

MAX POOL FLOW RATE: GALLONS / TURNOVER = FLOW RATE
25432 GAL / 360 minutes = 70.644444 GPM

POOL FEATURES
JETS, SHEER DE 0 WATER FEATURE GPM EA = 0 GPM
TOTAL SUGGESTED POOL FLOW RATE: 70.64 GPM

V = 1.318 C R^{0.63} S^{0.54}

SUPPLY (RETURN) PIPING

3 in = NOMINAL DIAMETER
3.04 in = D ACTUAL diam
0.2535 ft = D diam
140 = C, coefficient of roughness
7.2679 in² = A pipe
0.0505 ft² = A pipe
162.00 gpm / line = 0.3609626 cfs
162.00 gpm = TOTAL FLOW IN 1 LINES
0.3610 cfs = Q flow M
7.1518 f/sec = V = Velocity
0.0634 ft = R = Hydraulic Radius = A / P

0.0608 ft/ft = S hydraulic gradient
10 ft = pipe length average
0.61 ft = hf = head loss due to friction
0.26 psi

SUCTION PIPING

2 in = NOMINAL DIAMETER
2.05 in = D ACTUAL diam
0.1706 ft = D diam
140 = C, coefficient of roughness
3.2910 in² = A pipe
0.0229 ft² = A pipe
54.00 gpm = 0.1203209 cfs
3 No. of Suction Pipes
0.1203 cfs = Q flow rate
5.2648 f/sec = V = Velocity
0.0426 ft = R = Hydraulic Radius = A / P

0.0547 ft/ft = S hydraulic gradient
23 ft = pipe length average
1.26 ft = hf = head loss due to friction
0.54 psi

BRANCH P model

	FLOW GPM	STR FT	PSI
2 in @ 6 fps max BRANCH =	61.54 GPM	100.00	10.2
2 in @ 8 fps max TRUNK =	82.06 GPM	120.00	16.0
2 in @ 10 fps max RETURN =	102.57 GPM	140.00	25.4
3 in @ 3 fps max RETURN =	67.95 GPM MAIN	160.00	33.3
	DRAIN	180.00	37.0

OTHER PRESSURE LOSSES

19.00 FT = FILTER TDH LOSS
FT = HEATER TDH LOSS
19.00 FT = TOTAL TDH LOSS

MINOR LOSSES (SUPPLY & SUCTION COMBINED)

h (lost) = KL * V ² / (2*g)	K	h (lost) ft
2 ea = # tees thru side outlet	1.75	2.78
2 ea = # gate valves	1	1.59
1 ea = # check valves	0.2	0.16
0 THERAPY JET	21.73	0.00
0 ea = # 45 deg ELL	0.4	0.00
6 ea = # 90 deg ELL	0.75	3.57
0 ea = Reducer D2=	0.5	0.0871791
TOTAL =		8.10 ft

ELEVATION DIFFERENCE

0.00 ft = delta Z
model

4.67 FT = TOTAL FRICTION HEAD LOSS AFTER SPLIT @ LOOP

33.64 FT = TOTAL HEAD LOSS IN SYSTEM @ 162.00 GPM

14.56 PSI

PUMP SELECTION : JANDY 2.7 HP
model: VARIABLE SPEED

SUCTION OUTLET COVER: MUST EXCEED 162.00 GPM FLOW RATE
model 32" CHANNEL DRAIN OR 2 OUTLET COVERS

SYSTEM FLOW RATE MUST NOT EXCEED APPROVED COVER FLOW RATE O.K.
PER FBC 2023 8TH EDITION ANSI / APSP 13
MOTOR TO BE GFCI PROTECTED PER NEC 680.21©

