

OWILLIAM MYERS P.O. BOX 1513 LAKE CITY, FL 32056

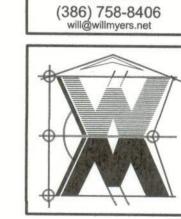

JOB NUMBER

SHEET NUMBER OF 3 SHEETS

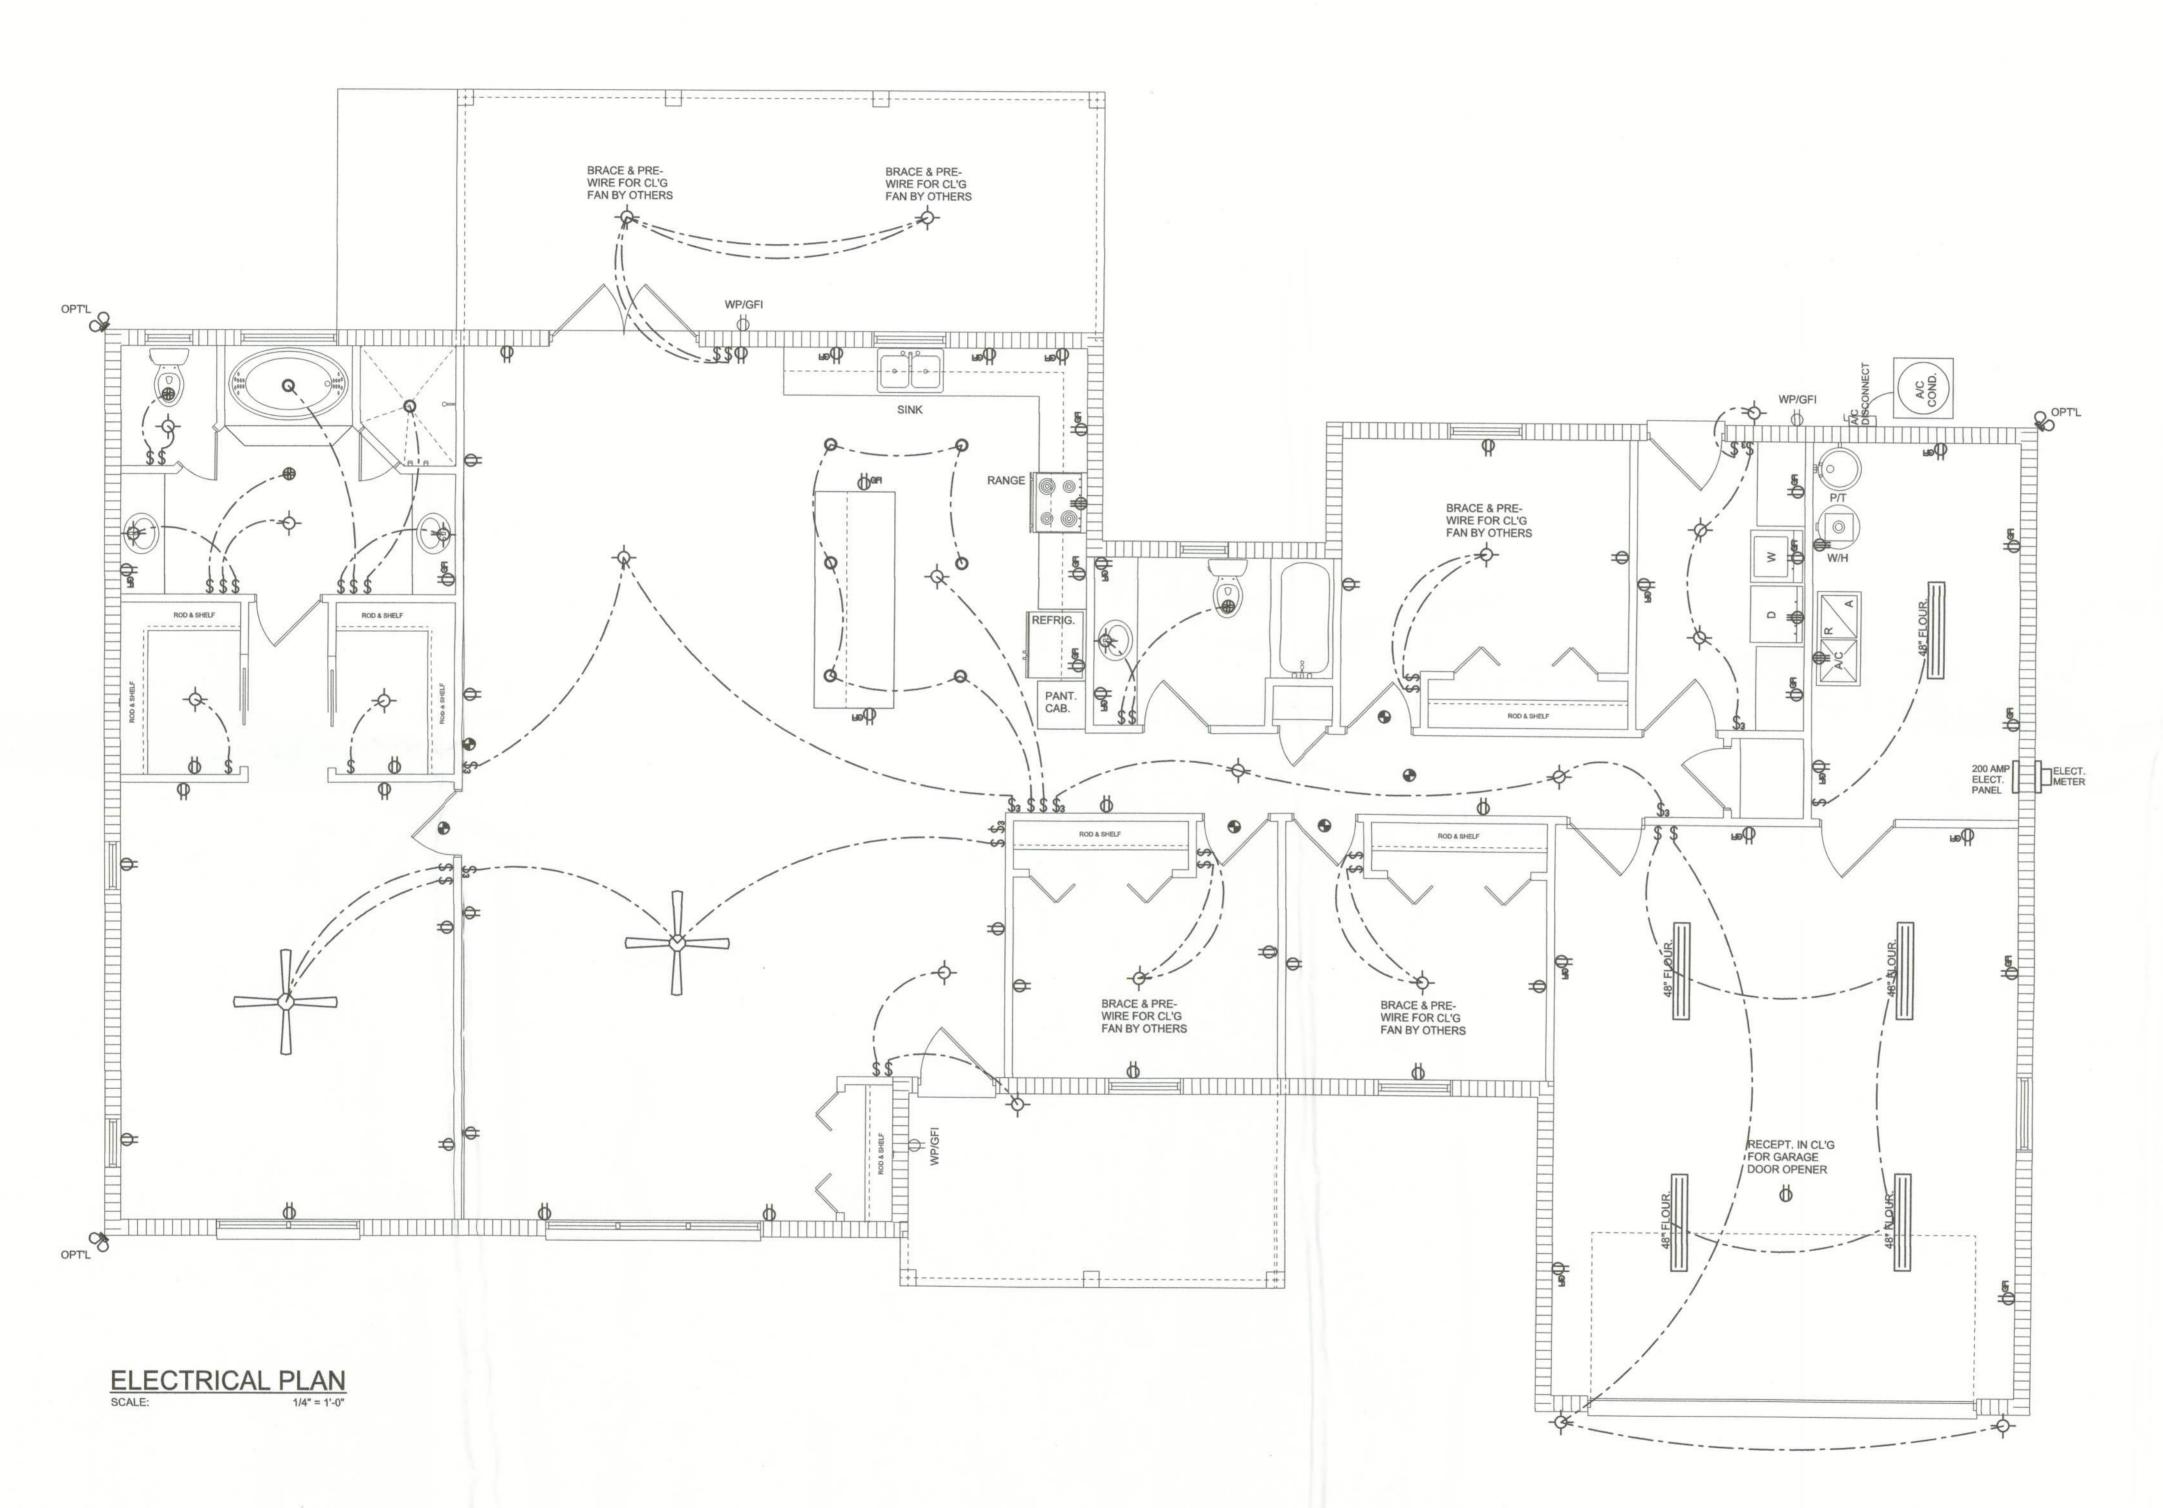

	ELECTRICAL LEGEND
	CEILING FAN (PRE-WIRE FOR LIGHT KIT)
QD	DOUBLE SECURITY LIGHT
0	RECESSED CAN LIGHT
₩	BATH EXHAUST FAN
	LIGHT FIXTURE
Ф	DUPLEX OUTLET (AFCI & TAMPER RESISTANT)
#	220v OUTLET
₩an	GFI DUPLEX OUTLET (PER NEC 406.8)
†	TELEVISION JACK
PH	TELEPHONE JACK
•	SMOKE / CARBON MONOXIDE DETECTOR (see note below
\$	WALL SWITCH
\$3	3 WAY WALL SWITCH
₩P/GFI	WATER PROOF GFI OUTLET
48" FLOUR.	2 OR 4 TUB FLUORESCENT FIXTURE

ALL INTERIOR RECEPTACLES SHALL BE AFCI (ARC FAULT CIRCUIT INTERRUPT) PER NEC 210.12 & TAMPER RESISTANT PER

ALL SMOKE DETECTORS BE A COMBO SMOKE & CARBON MONOXIDE DETECTOR AND SHALL HAVE BATTERY BACKUP POWER AND ALL WIRED TOGETHER SO IF ANY ONE UNIT IS ACTUATED THEY ALL ACTIVATE.

THE ELECTRICAL SERVICE OVERCURRENT PROTECTION DEVICE SHALL BE INSTALLED ON THE EXTERIOR OF STRUCTURES TO SERVE AS A DISCONNECT MEANS. CONDUCTORS USED FROM THE EXTERIOR DISCONNECTING MEANS TO A PANEL OR SUB PANEL SHALL HAVE FOUR-WIRE CONDUCTORS, OF WHICH ONE CONDUCTOR SHALL BE USED AS AN EQUIPMENT GROUND.

IT IS THE LICENSED ELECTRICAL CONTRACTORS RESPONSIBILITY TO INSURE THAT ALL WORK PERFORMED AND EQUIPMENT INSTALLED MEETS OR EXCEEDS THE 2008 NATIONAL ELECTRIC CODE AND ALL OTHER LOCAL CODES AND ORDINANCES.