
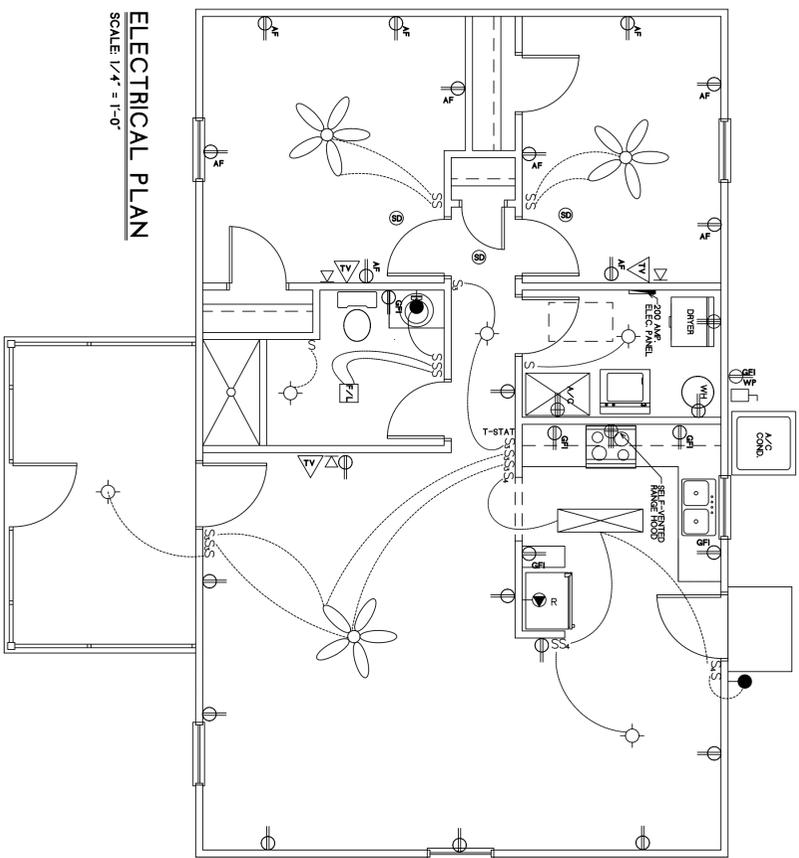
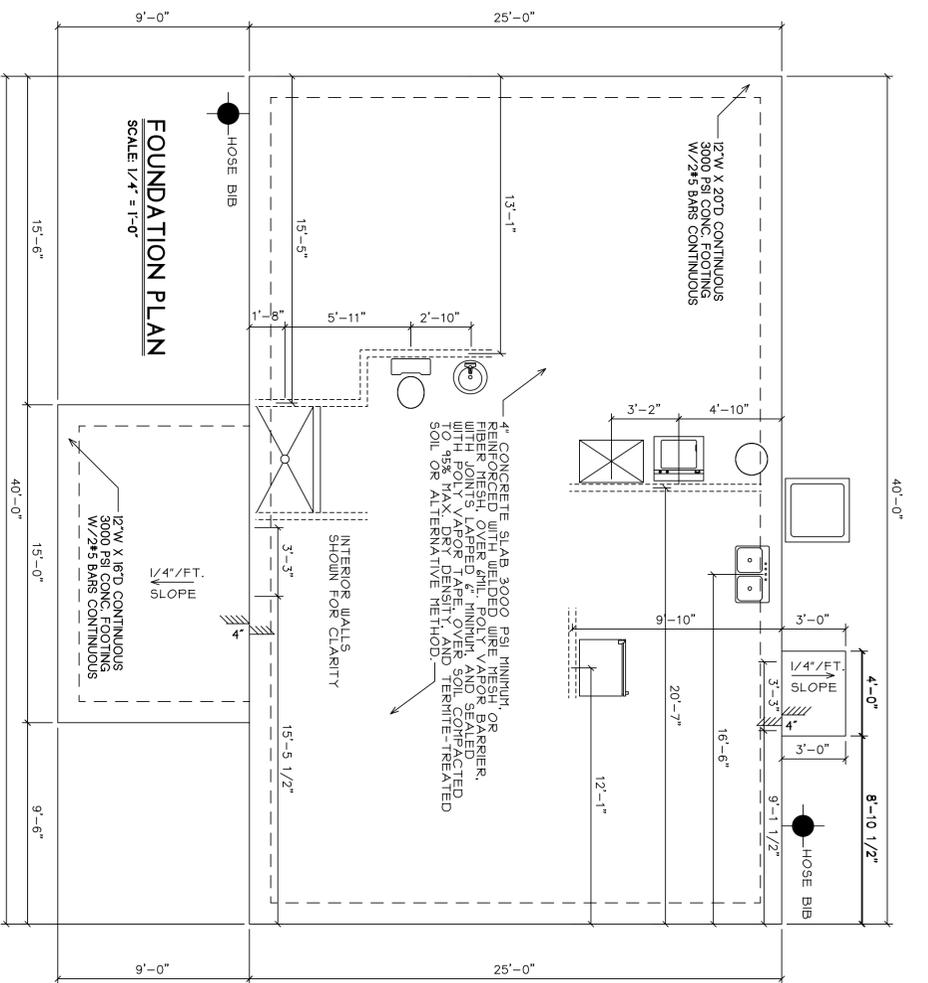
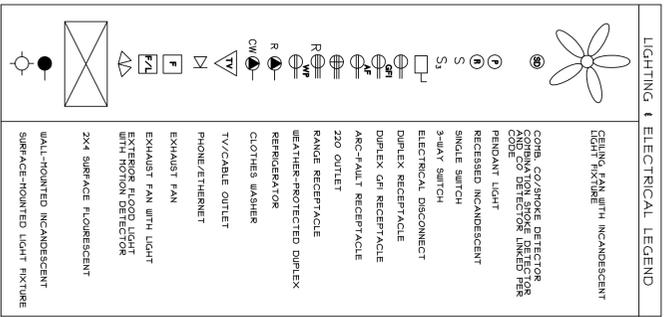
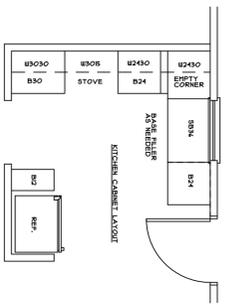


Dan & Zarsa Cannon
130 SW Plymouth Ave
Fort White, FL 32038

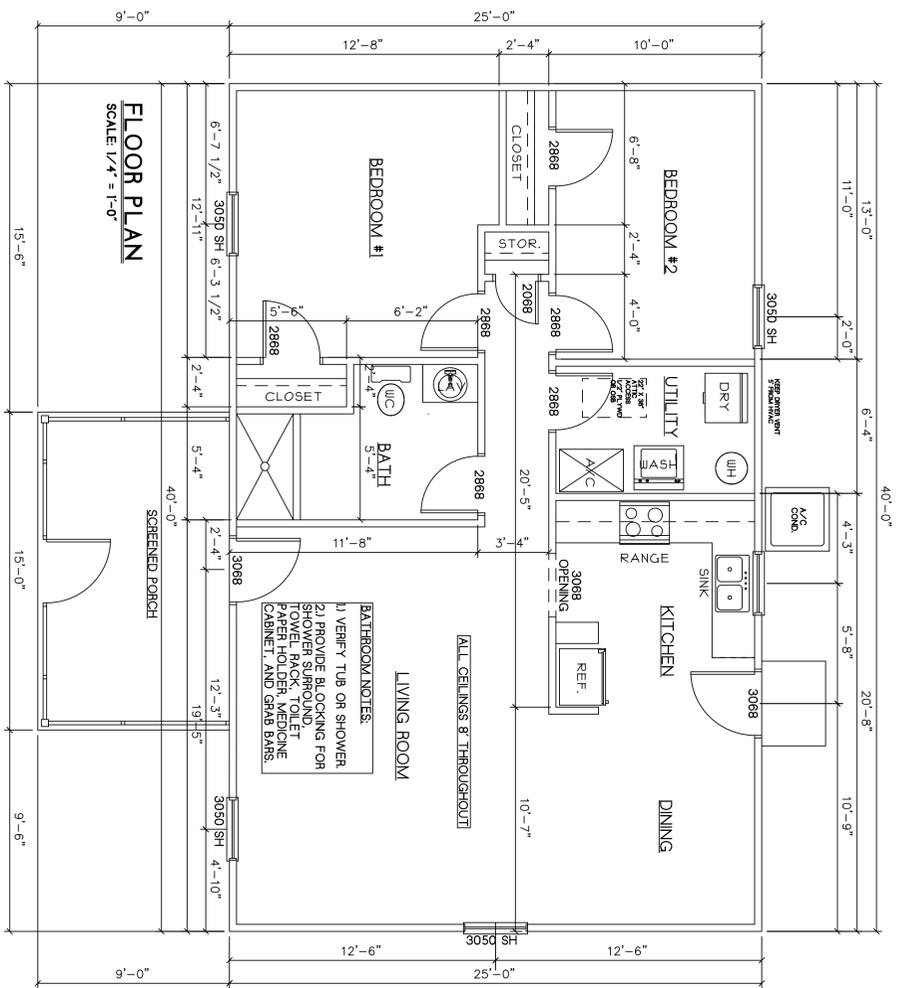

This item has been digitally signed and sealed by FRANK J SAPIENZA JR PE using Digital Signature.
Printed copies of this document are not considered signed and sealed and the signature must be verified on any electronic copies.

CUSTOMER NAME:

FLA HOMES, INC. R/C

13919 NW 145TH AVENUE, ALACHUA, FLORIDA 32615
(386)418-4863 flahomes@windstream.net LICENSE #: CGC 052062

1 of 2
SHEET NUMBER

PLAN NAME:
Bay V Model

SCALE: **1/4" = 1'-0"**
UNLESS OTHERWISE NOTED

AREA SUMMARY	
H/C:	1000
FRONT PORCH:	135
TOTAL:	1135




ALL WORK SHALL COMPLY WITH CURRENT FLORIDA BUILDING AND ELECTRICAL CODE
*THESE PLANS AND NOTES ARE THE PROPERTY AND SOLE RESPONSIBILITY OF FLA HOMES, INC. USE OF THESE PLANS WITHOUT THE WRITTEN CONSENT OF FLA HOMES, INC. IS PROHIBITED.
*THESE PLANS ARE SUBJECT TO MODIFICATION AS NECESSARY TO MEET CODE REQUIREMENTS OR TO FACILITATE MECHANICAL INSTALLATIONS OR TO INCORPORATE DESIGN IMPROVEMENTS. THE BUILDER RESERVES THE RIGHT TO MAKE ANY CHANGES FOR ANY REASON, AT ANY TIME, PROVIDING THE CHANGES COMPLY WITH APPLICABLE LOCAL CODES.
*THE SUBCONTRACTOR SHALL COMPARE AND COORDINATE ALL DRAWINGS. WHEN A DISCREPANCY, ERROR, OR OMISSION EXISTS, THE SUBCONTRACTOR SHALL COMPLY WITH APPLICABLE LOCAL CODES AND CONTACT THE BUILDER IN WRITING FOR PROPER ADJUSTMENT.

REVISION DATE
JUNE 29, 2025

SUBDIVISION:
LOT #:

DRAWN BY:
Steve Ryals CAD Services
2850 La Salle Lake Road
Conroe, TX 77304
(505)717-6251
sryals@gmail.com

PAGE CONTENT:
**FLOOR PLAN
ELECTRICAL PLAN
FOUNDATION PLAN
KITCHEN CABINET LAYOUT**

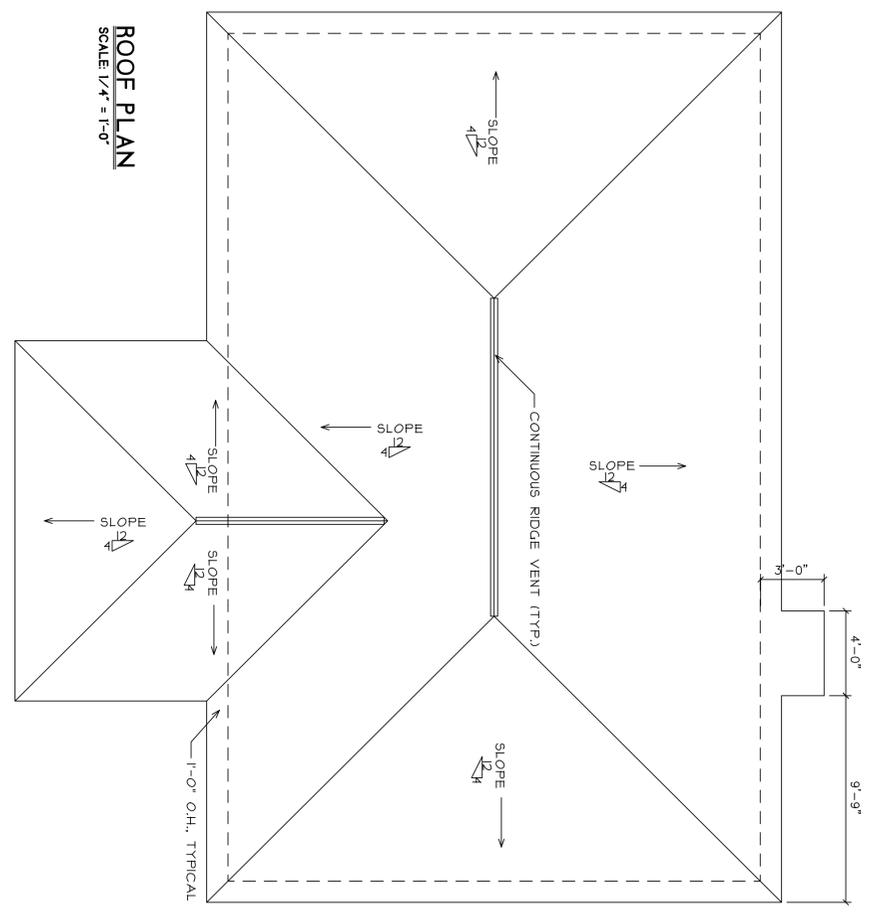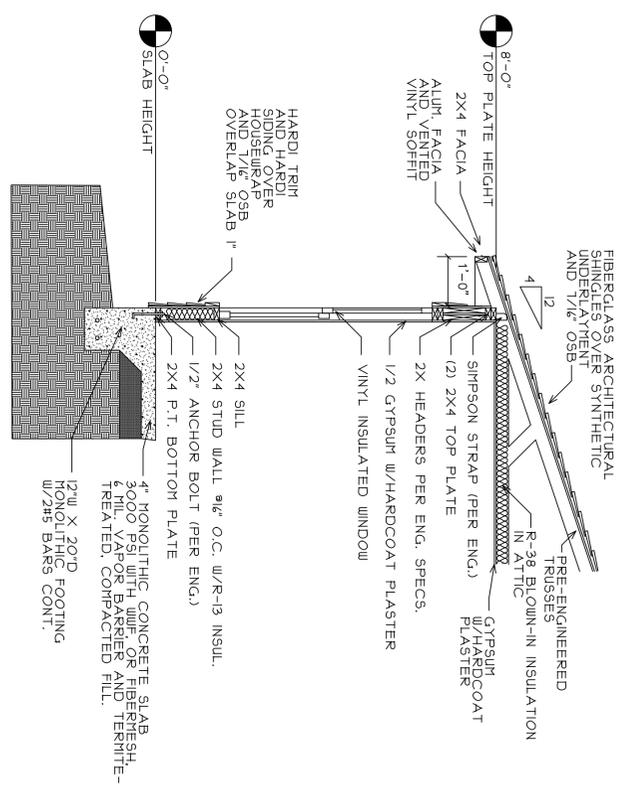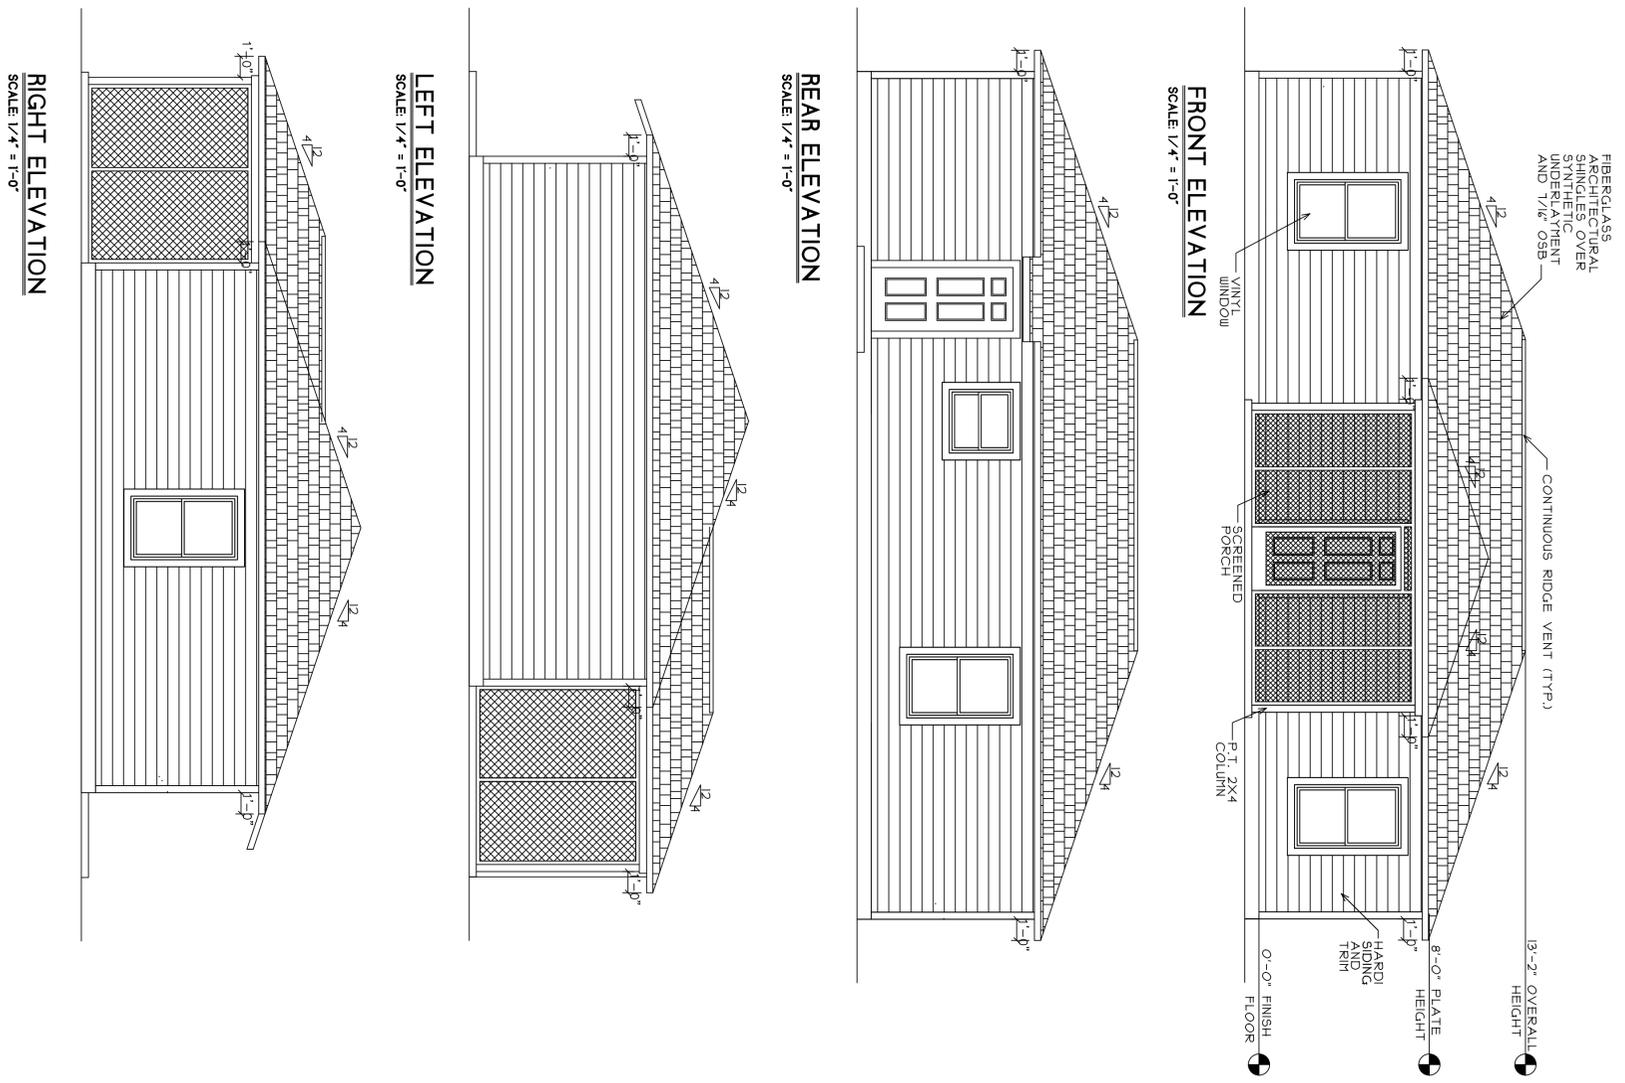

CUSTOMER NAME: **FLA HOMES, INC. R/C** 13919 NW 145TH AVENUE, ALACHUA, FLORIDA 32615 (386)418-4663 flahomes@windstream.net LICENSE #: CGC 052062

2 of 2	PLAN NAME: Bay V Model	AREA SUMMARY	*ALL WORK SHALL COMPLY WITH CURRENT FLORIDA BUILDING AND ELECTRICAL CODE *THESE PLANS AND NOTES ARE THE PROPERTY AND SOLE RESPONSIBILITY OF FLA HOMES, INC. USE OF THESE PLANS WITHOUT THE WRITTEN CONSENT OF FLA HOMES, INC. IS PROHIBITED. *THESE PLANS ARE SUBJECT TO MODIFICATION AS NECESSARY TO MEET CODE REQUIREMENTS OR TO FACILITATE MECHANICAL INSTALLATIONS OR TO INCORPORATE DESIGN IMPROVEMENTS. THE BUILDER RESERVES THE RIGHT TO MAKE ANY CHANGES FOR ANY REASON AT ANY TIME, PROVIDING THE CHANGES COMPLY WITH APPLICABLE LOCAL CODES. *THE SUBCONTRACTOR SHALL COMPLY AND COORDINATE ALL DRAWINGS. WHEN A DISCREPANCY, ERROR, OR OMISSION EXISTS, THE SUBCONTRACTOR SHALL COMPLY WITH APPLICABLE LOCAL CODES AND CONTACT THE BUILDER IN WRITING FOR PROPER ADJUSTMENT.	REVISION DATE JUNE 29, 2025	SUBDIVISION: LOT #:	PAGE CONTENT: EXTERIOR ELEVATIONS WALL SECTION ROOF PLAN			
	SHEET NUMBER	SCALE: 1/4" = 1'-0" UNLESS OTHERWISE NOTED		<table border="1"> <tr><td>H/C:</td><td>1000</td></tr> <tr><td>FRONT PORCH:</td><td>135</td></tr> <tr><td>TOTAL:</td><td>1135</td></tr> </table>	H/C:		1000	FRONT PORCH:	135
H/C:	1000								
FRONT PORCH:	135								
TOTAL:	1135								