


401 NW NOEGEL RD

N 01°20'25" W 285.000'

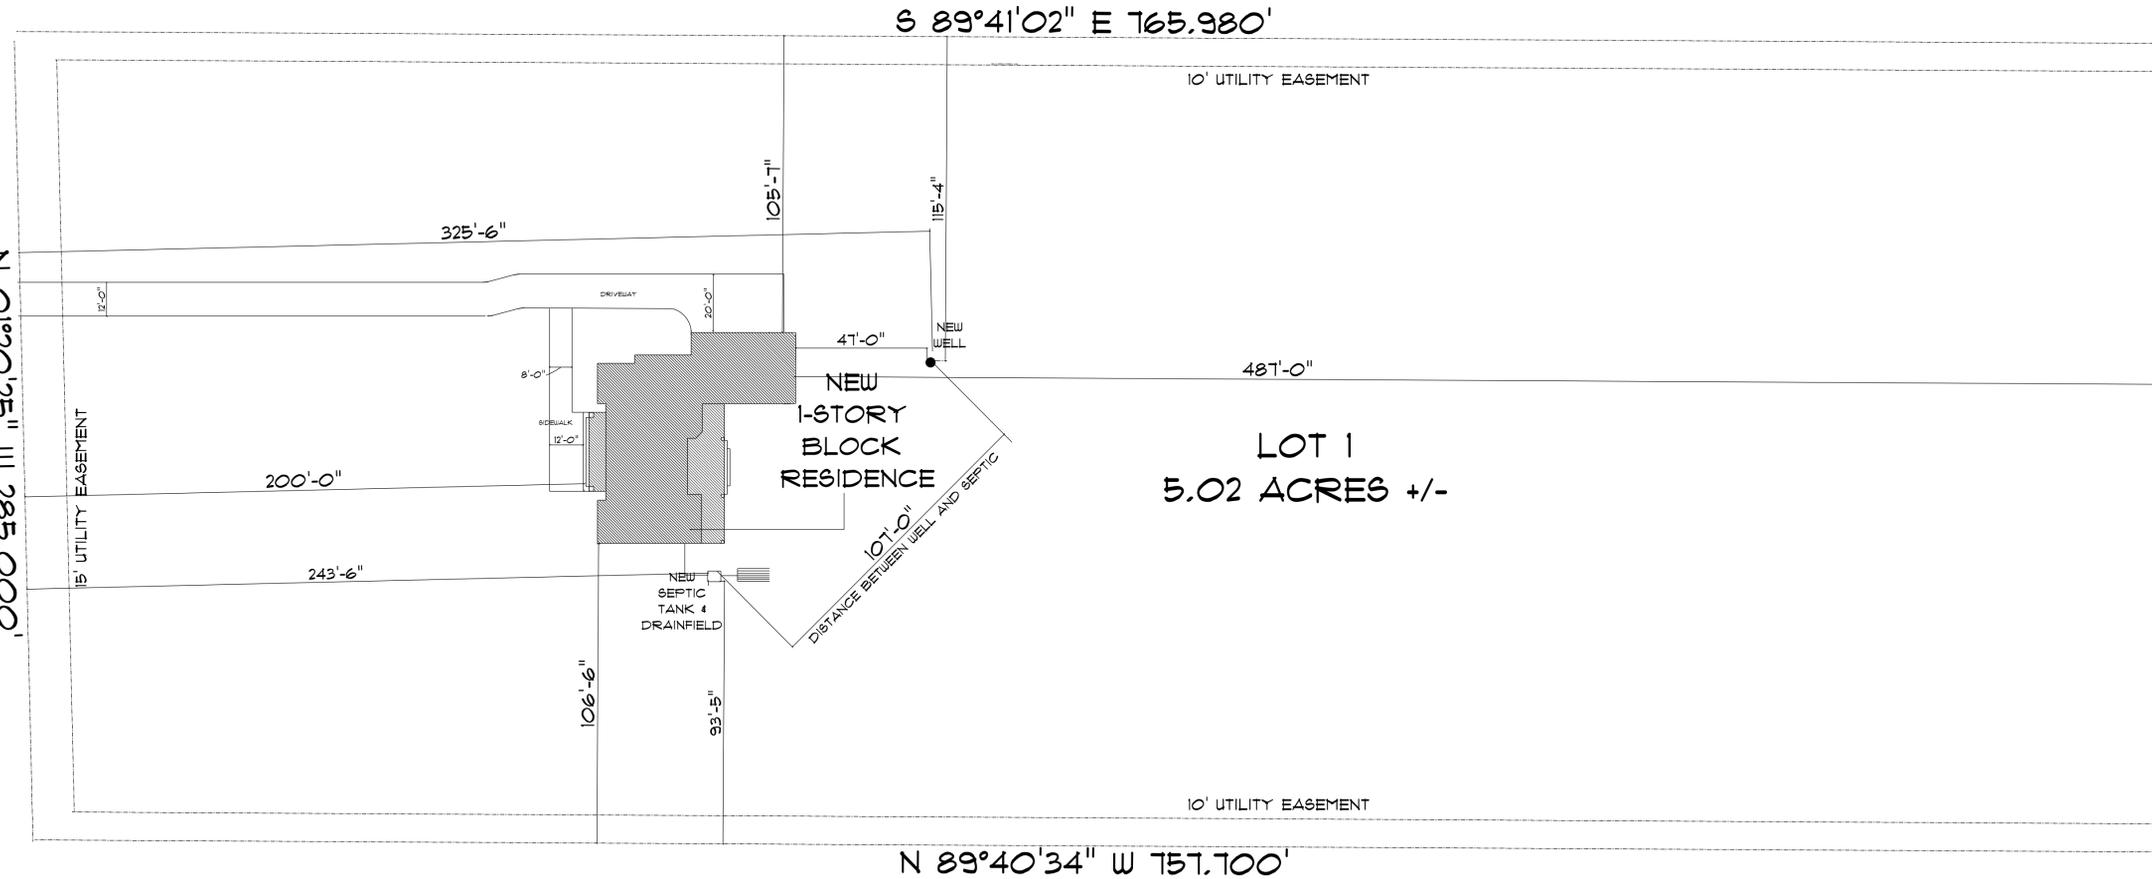

*** SITE PLAN ***

SCALE : 1" = 30'-0"



NEW RESIDENCE
for
CASSANDRA & MAURICE
SPATES
LAKE CITY, FLORIDA

Teena M. Ruffo
2925 SW SR 47
Lake City Florida, 32025
Cell: (386) 867-1191
Email: teenaruffo@gmail.com

PRINTED DATE:
Wednesday, October 15, 2025

DRAWN BY: Teena M. Ruffo
CHECKED BY:

BUILDING CONTRACTOR


FINALS DATE:

JOB NUMBER:

DRAWING NUMBER

A-1

OF 6 SHEETS

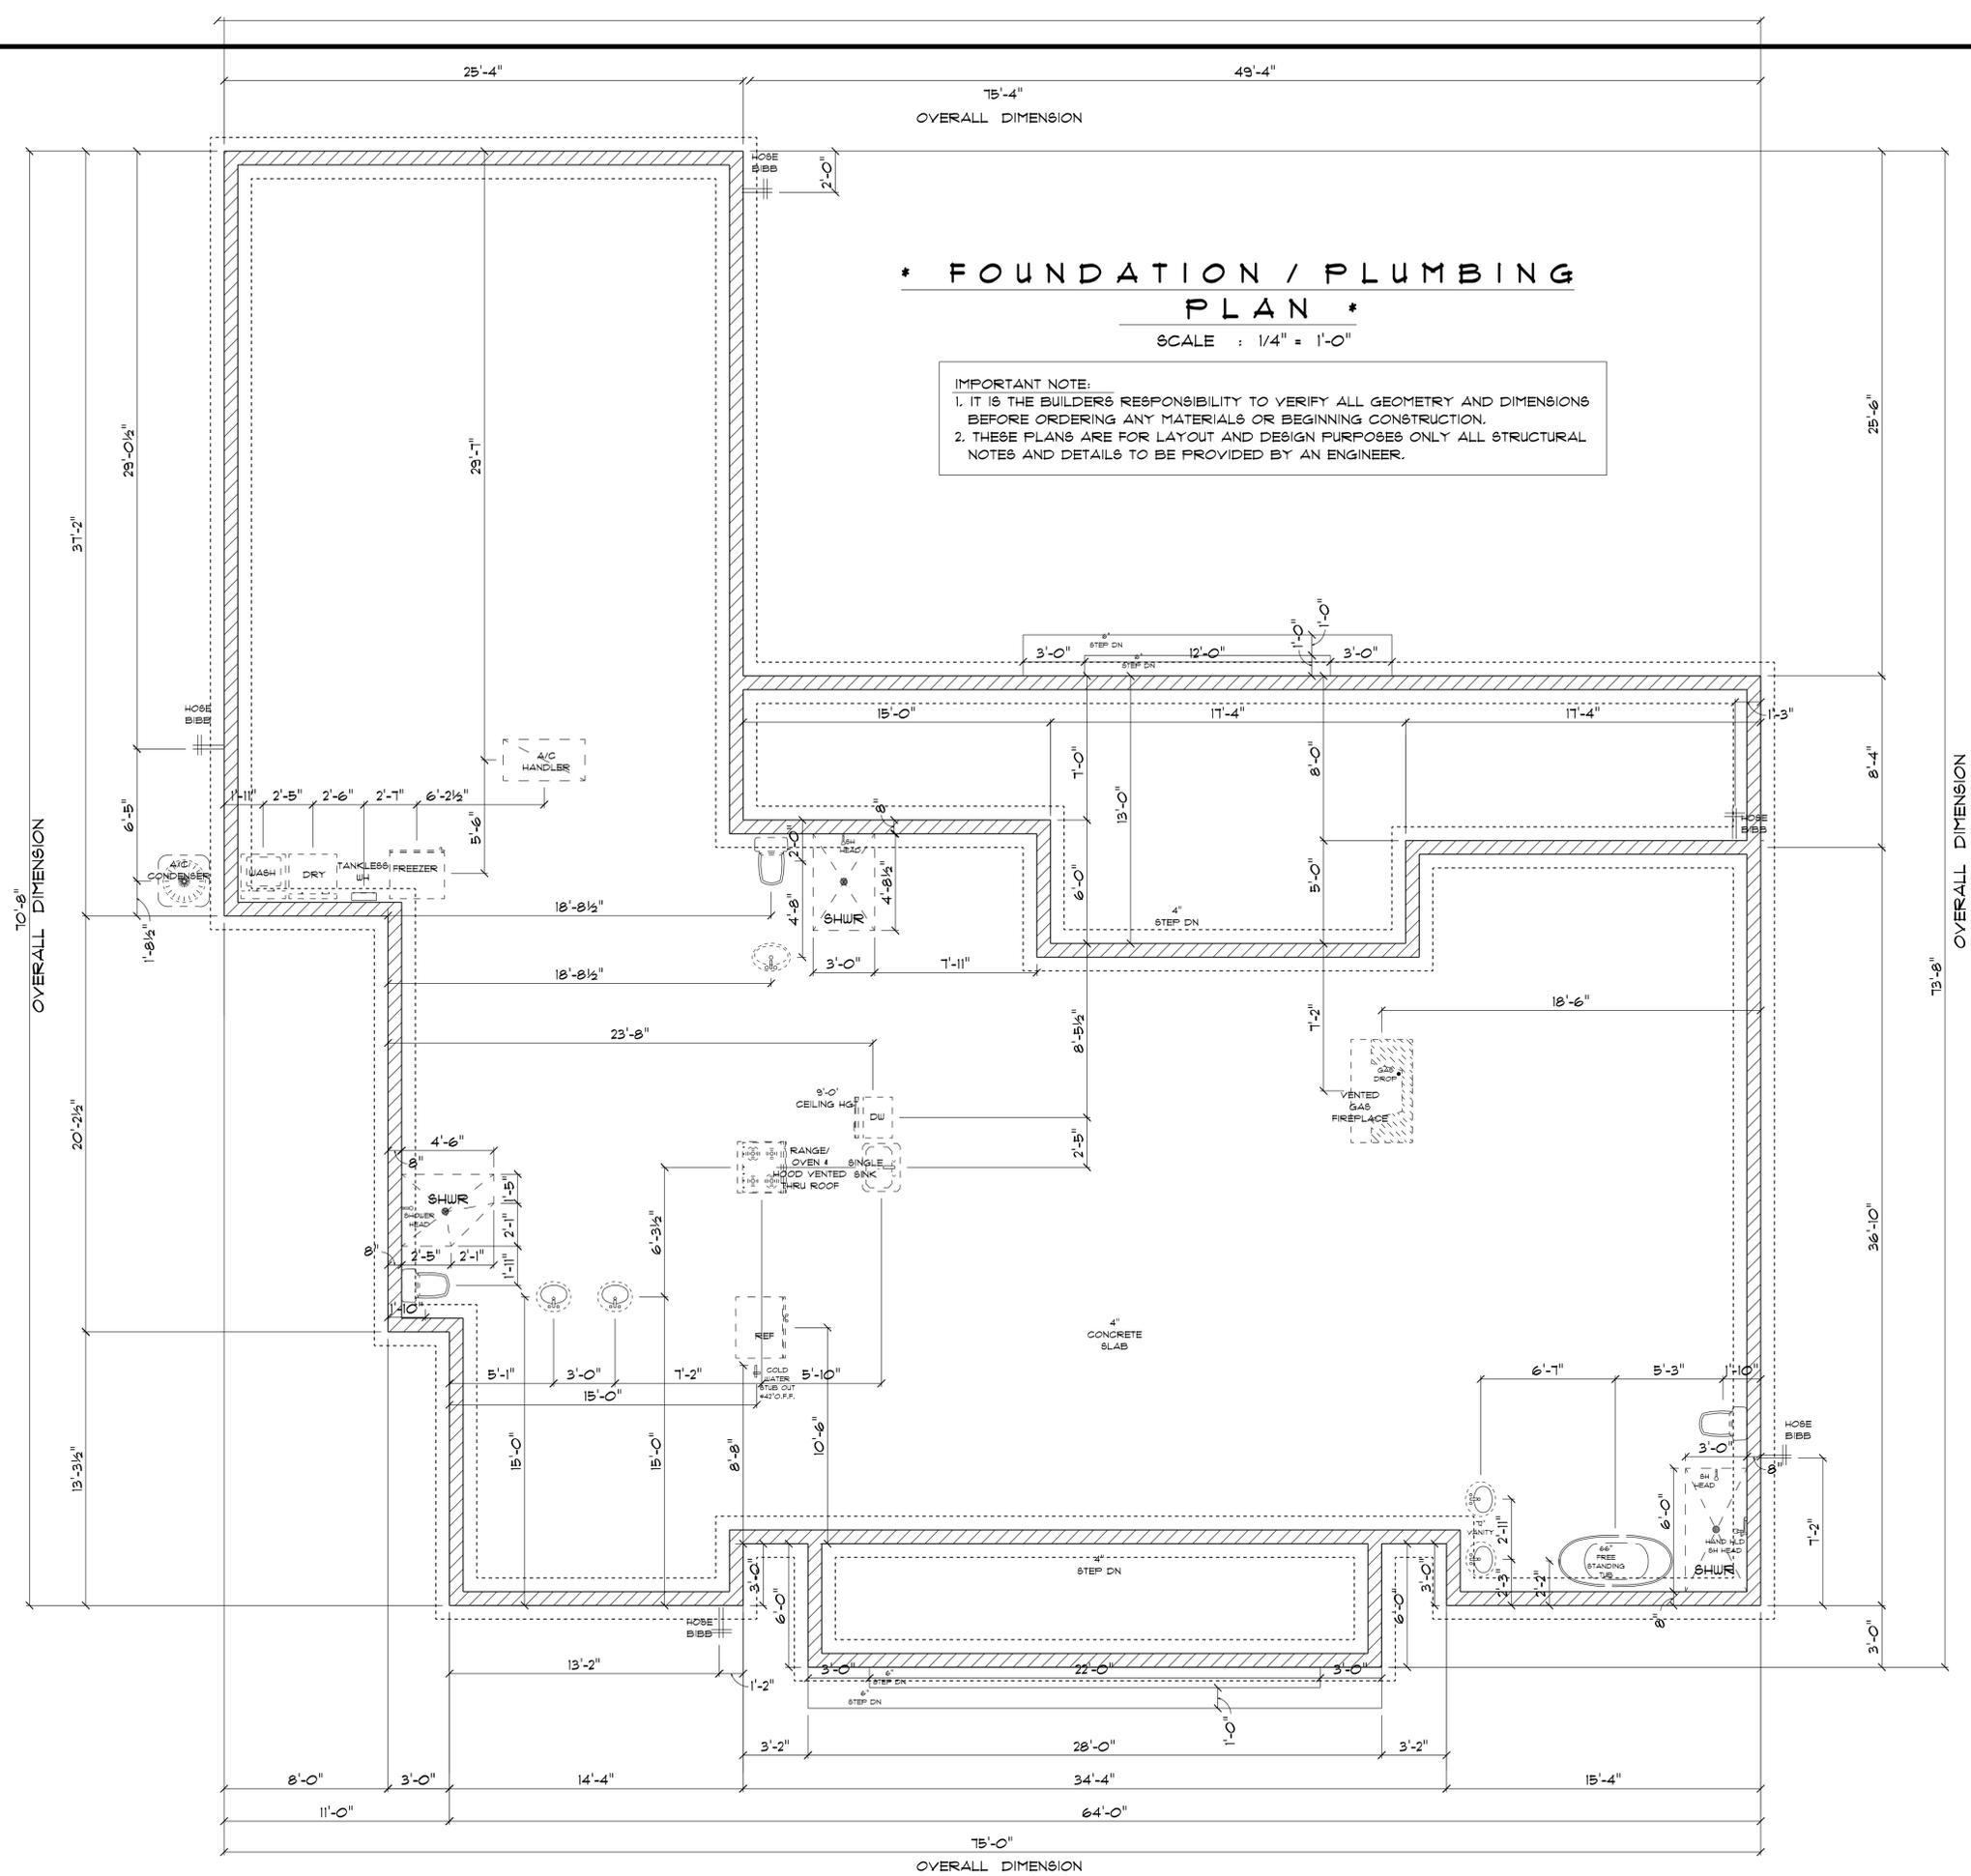

NEW RESIDENCE
for
CASSANDRA & MAURICE SPATES
LAKE CITY, FLORIDA

Teena M. Ruffo
2825 SW SR 47
Lake City Florida, 32025
Cell: (386) 861-1191
Email: teenaruffo@gmail.com

PRINTED DATE:
Wednesday, October 15, 2025

DRAWN BY: Teena M. Ruffo
CHECKED BY:


BUILDING CONTRACTOR

FINAL DATE:

JOB NUMBER:

DRAWING NUMBER
A-2

OF 6 SHEETS

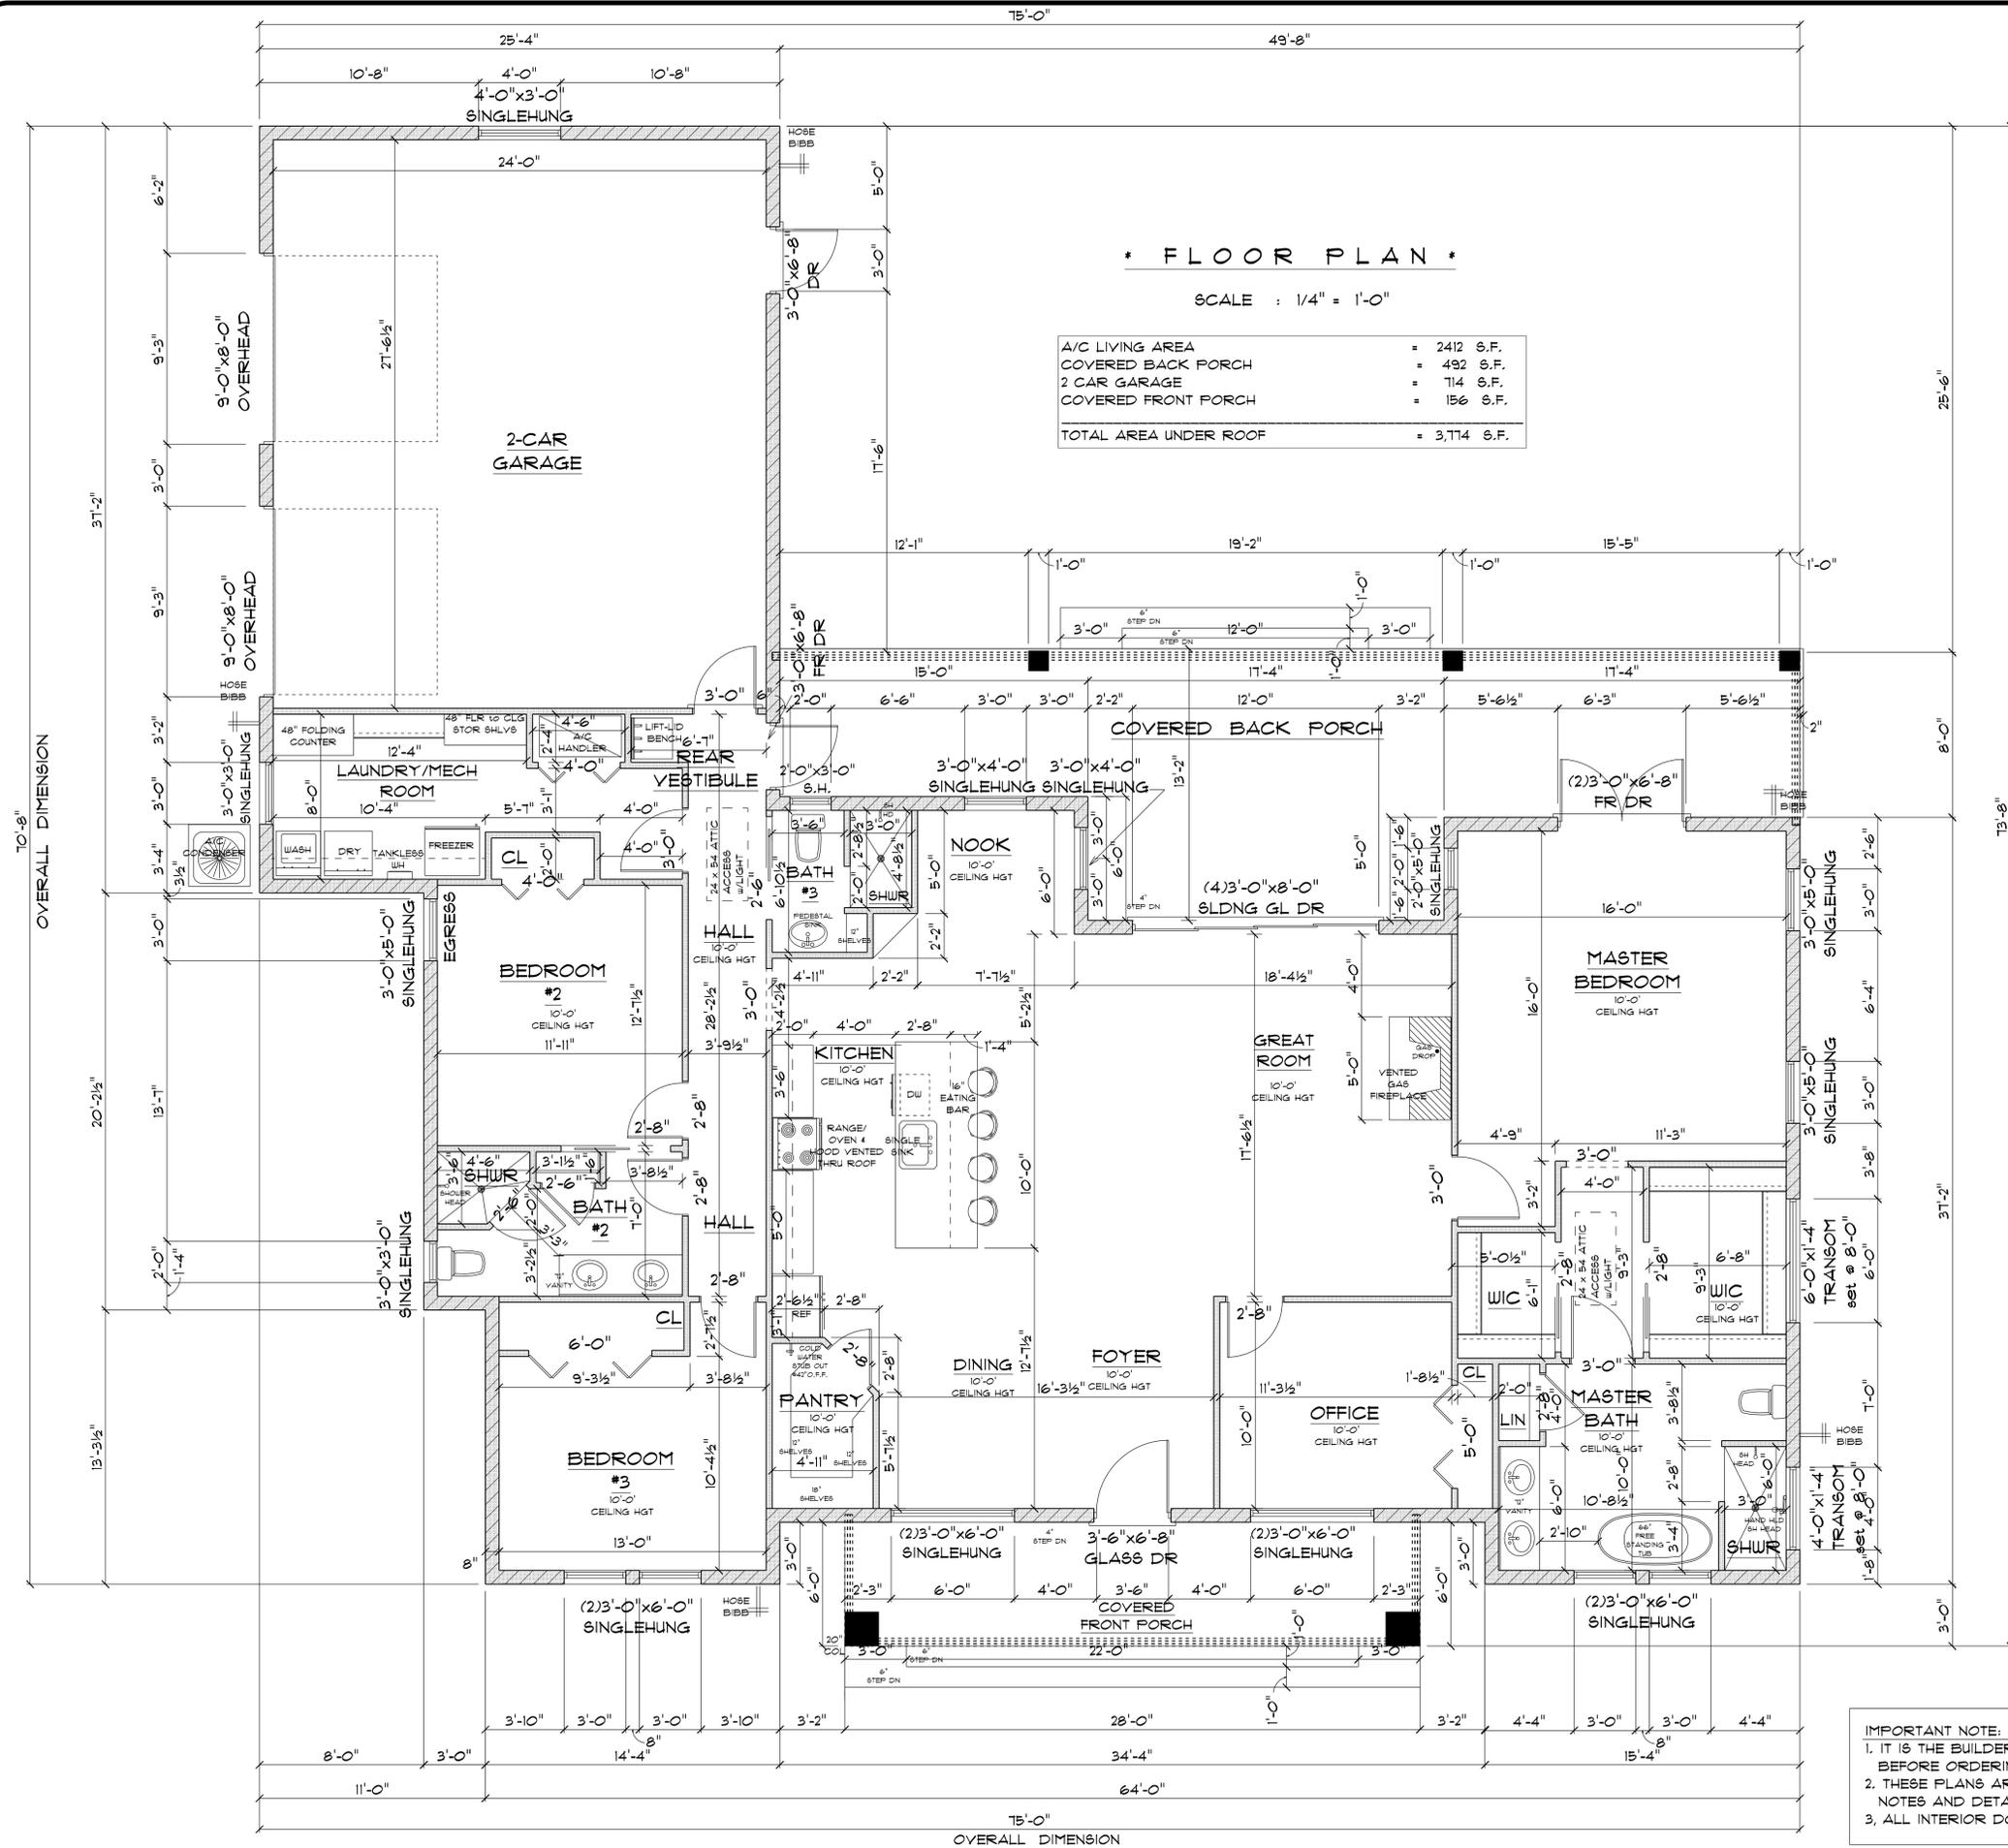


IMPORTANT NOTE:

1. IT IS THE BUILDER'S RESPONSIBILITY TO VERIFY ALL GEOMETRY AND DIMENSIONS BEFORE ORDERING ANY MATERIALS OR BEGINNING CONSTRUCTION.
2. THESE PLANS ARE FOR LAYOUT AND DESIGN PURPOSES ONLY ALL STRUCTURAL NOTES AND DETAILS TO BE PROVIDED BY AN ENGINEER.
3. ALL INTERIOR DOORS TO BE 6'-8"

NEW RESIDENCE
for
CASSANDRA & MAURICE SPATES
LAKE CITY, FLORIDA


Teena M. Ruffo
2925 6th St. 41
Lake City Florida, 32025
Cell: (386) 861-1191
Email: teenaruffo@gmail.com

PRINTED DATE: Wednesday, October 15, 202	
DRAWN BY: Teena M. Ruffo	CHECKED BY:
BUILDING CONTRACTOR	
FINALS DATE:	
JOB NUMBER:	
DRAWING NUMBER A-3	
OF 6 SHEETS	

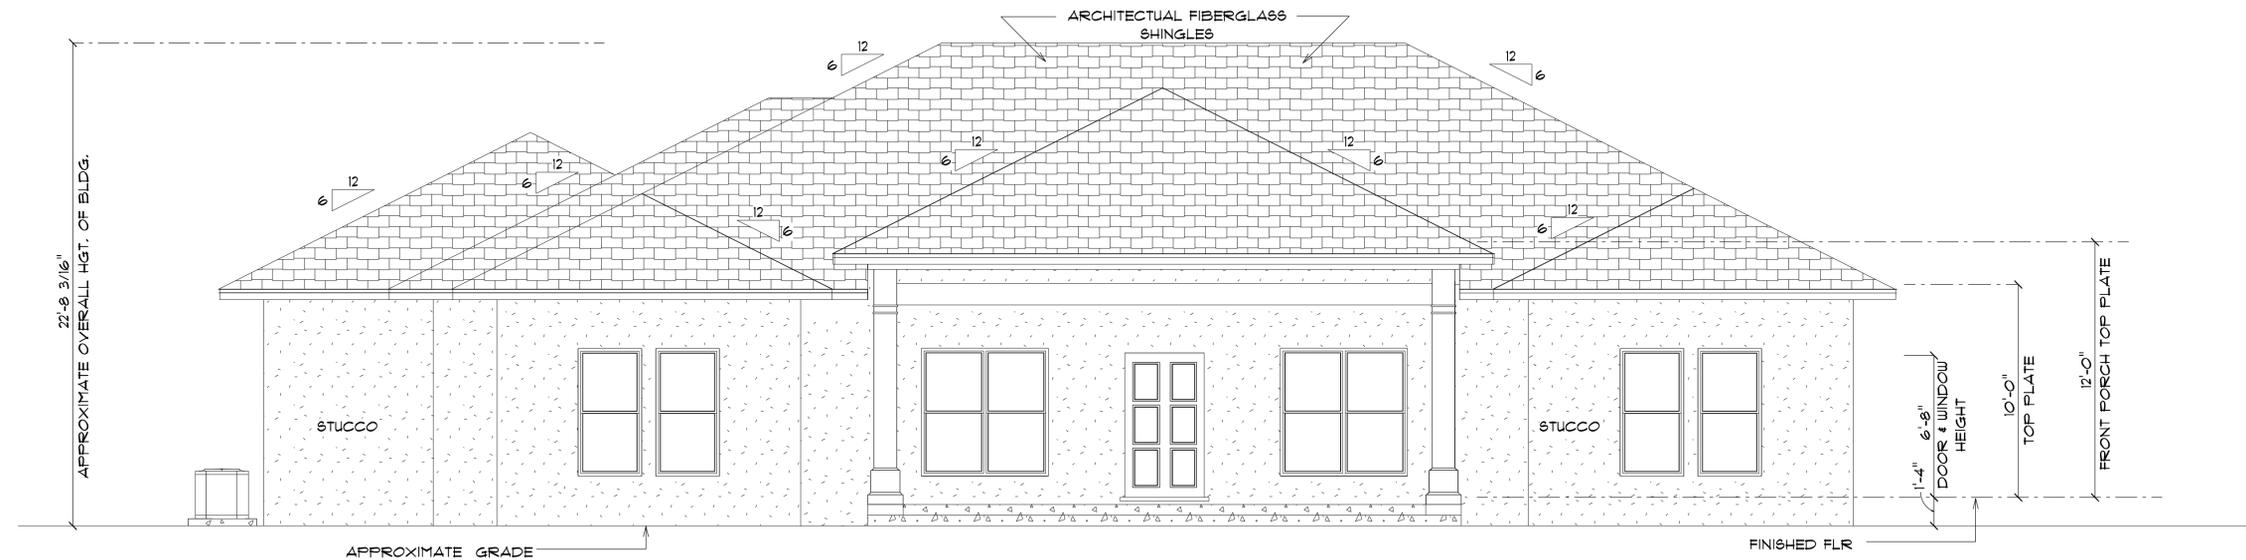

*** FRONT ELEVATION ***

SCALE : 1/4" = 1'-0" NOTE: 24" OVERHANG ON ALL EAVES

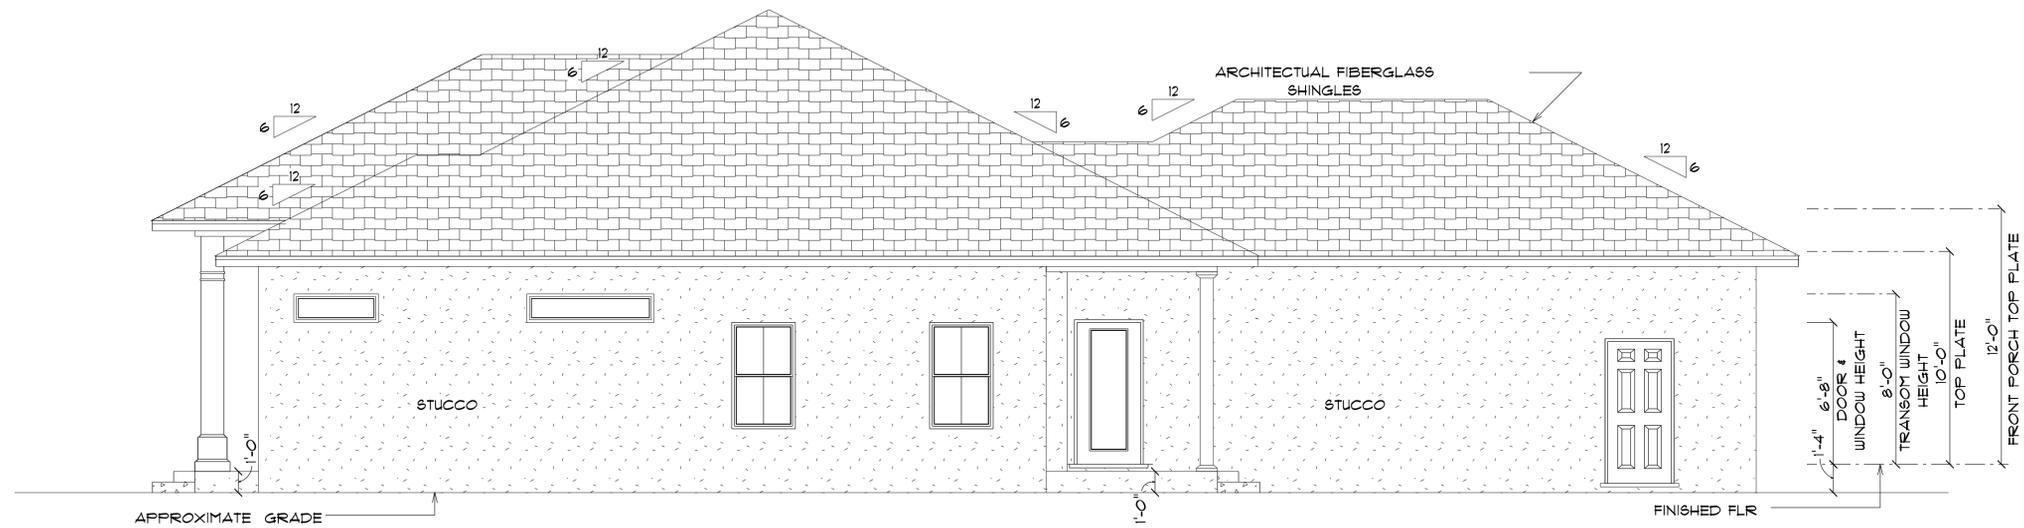

*** RIGHT ELEVATION ***

SCALE : 1/4" = 1'-0" NOTE: 24" OVERHANG ON ALL EAVES

NEW RESIDENCE
for
CASSANDRA & MAURICE
SPATES
LAKE CITY, FLORIDA

Teena M. Ruffo
2925 SW SR 41
Lake City Florida, 32025
Cell: (386) 861-1191
Email: teenaruffo@gmail.com

PRINTED DATE:
Wednesday, October 15, 2025

DRAWN BY: Teena M. Ruffo CHECKED BY:

BUILDING CONTRACTOR


FINALS DATE:

JOB NUMBER:

DRAWING NUMBER


A-4

OF 6 SHEETS

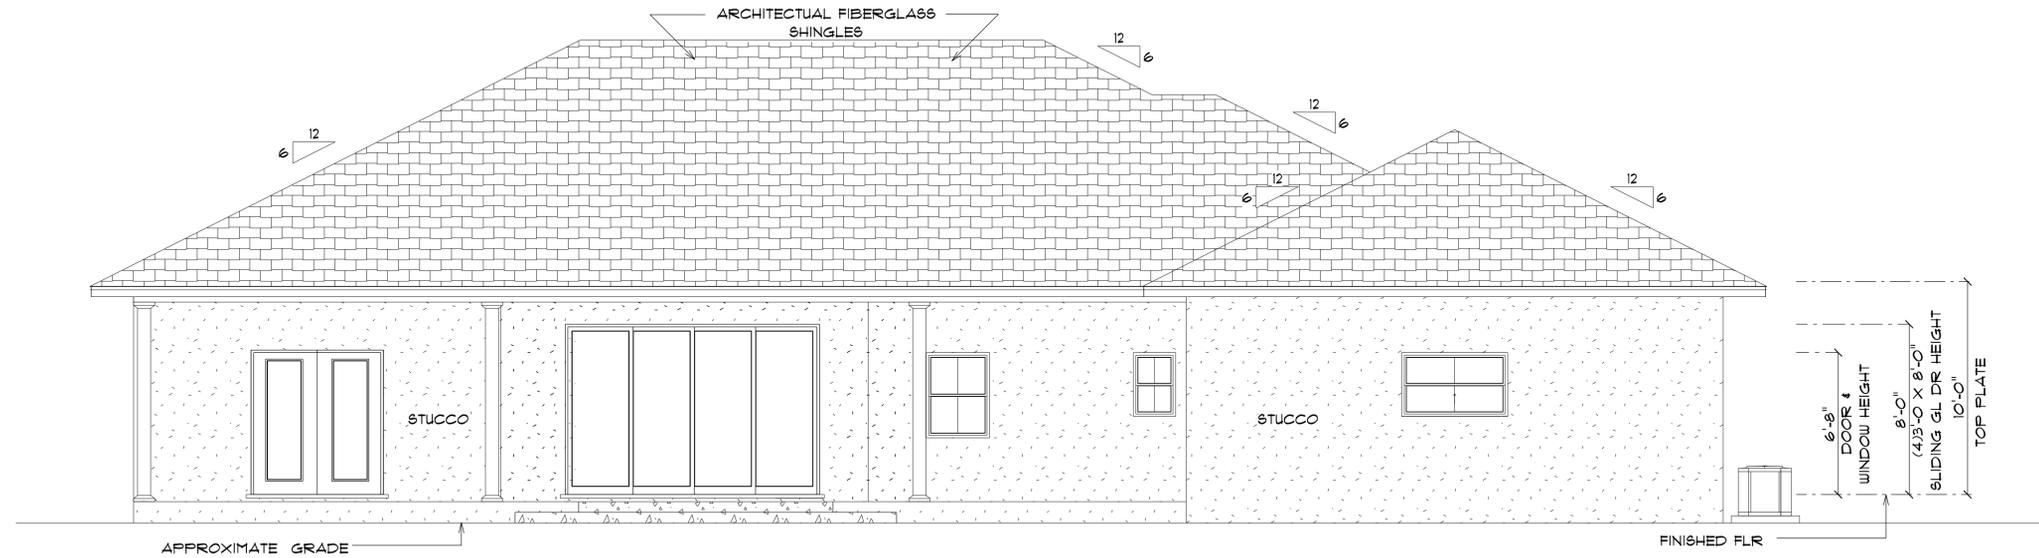

*** REAR ELEVATION ***

SCALE : 1/4" = 1'-0" NOTE: 24" OVERHANG ON ALL EAVES

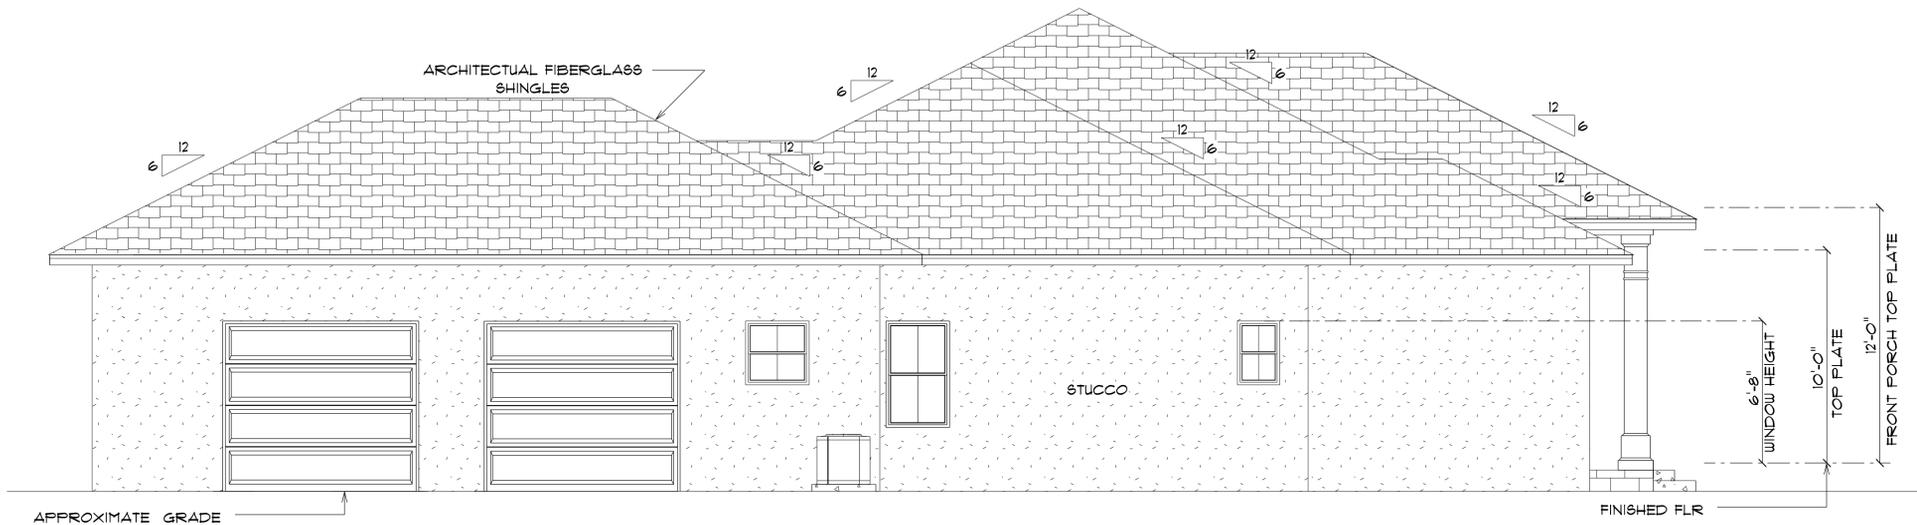

*** LEFT ELEVATION ***

SCALE : 1/4" = 1'-0" NOTE: 24" OVERHANG ON ALL EAVES

NEW RESIDENCE
for
CASSANDRA & MAURICE
SPATES
LAKE CITY, FLORIDA

Teena M. Ruffo
2925 SW SR 41
Lake City Florida, 32025
Cell: (386) 867-1191
Email: teenaruffo@gmail.com

PRINTED DATE:
Wednesday, October 15, 2025

DRAWN BY: Teena M. Ruffo CHECKED BY:

BUILDING CONTRACTOR


FINALS DATE:

JOB NUMBER:

DRAWING NUMBER

A-5

OF 6 SHEETS

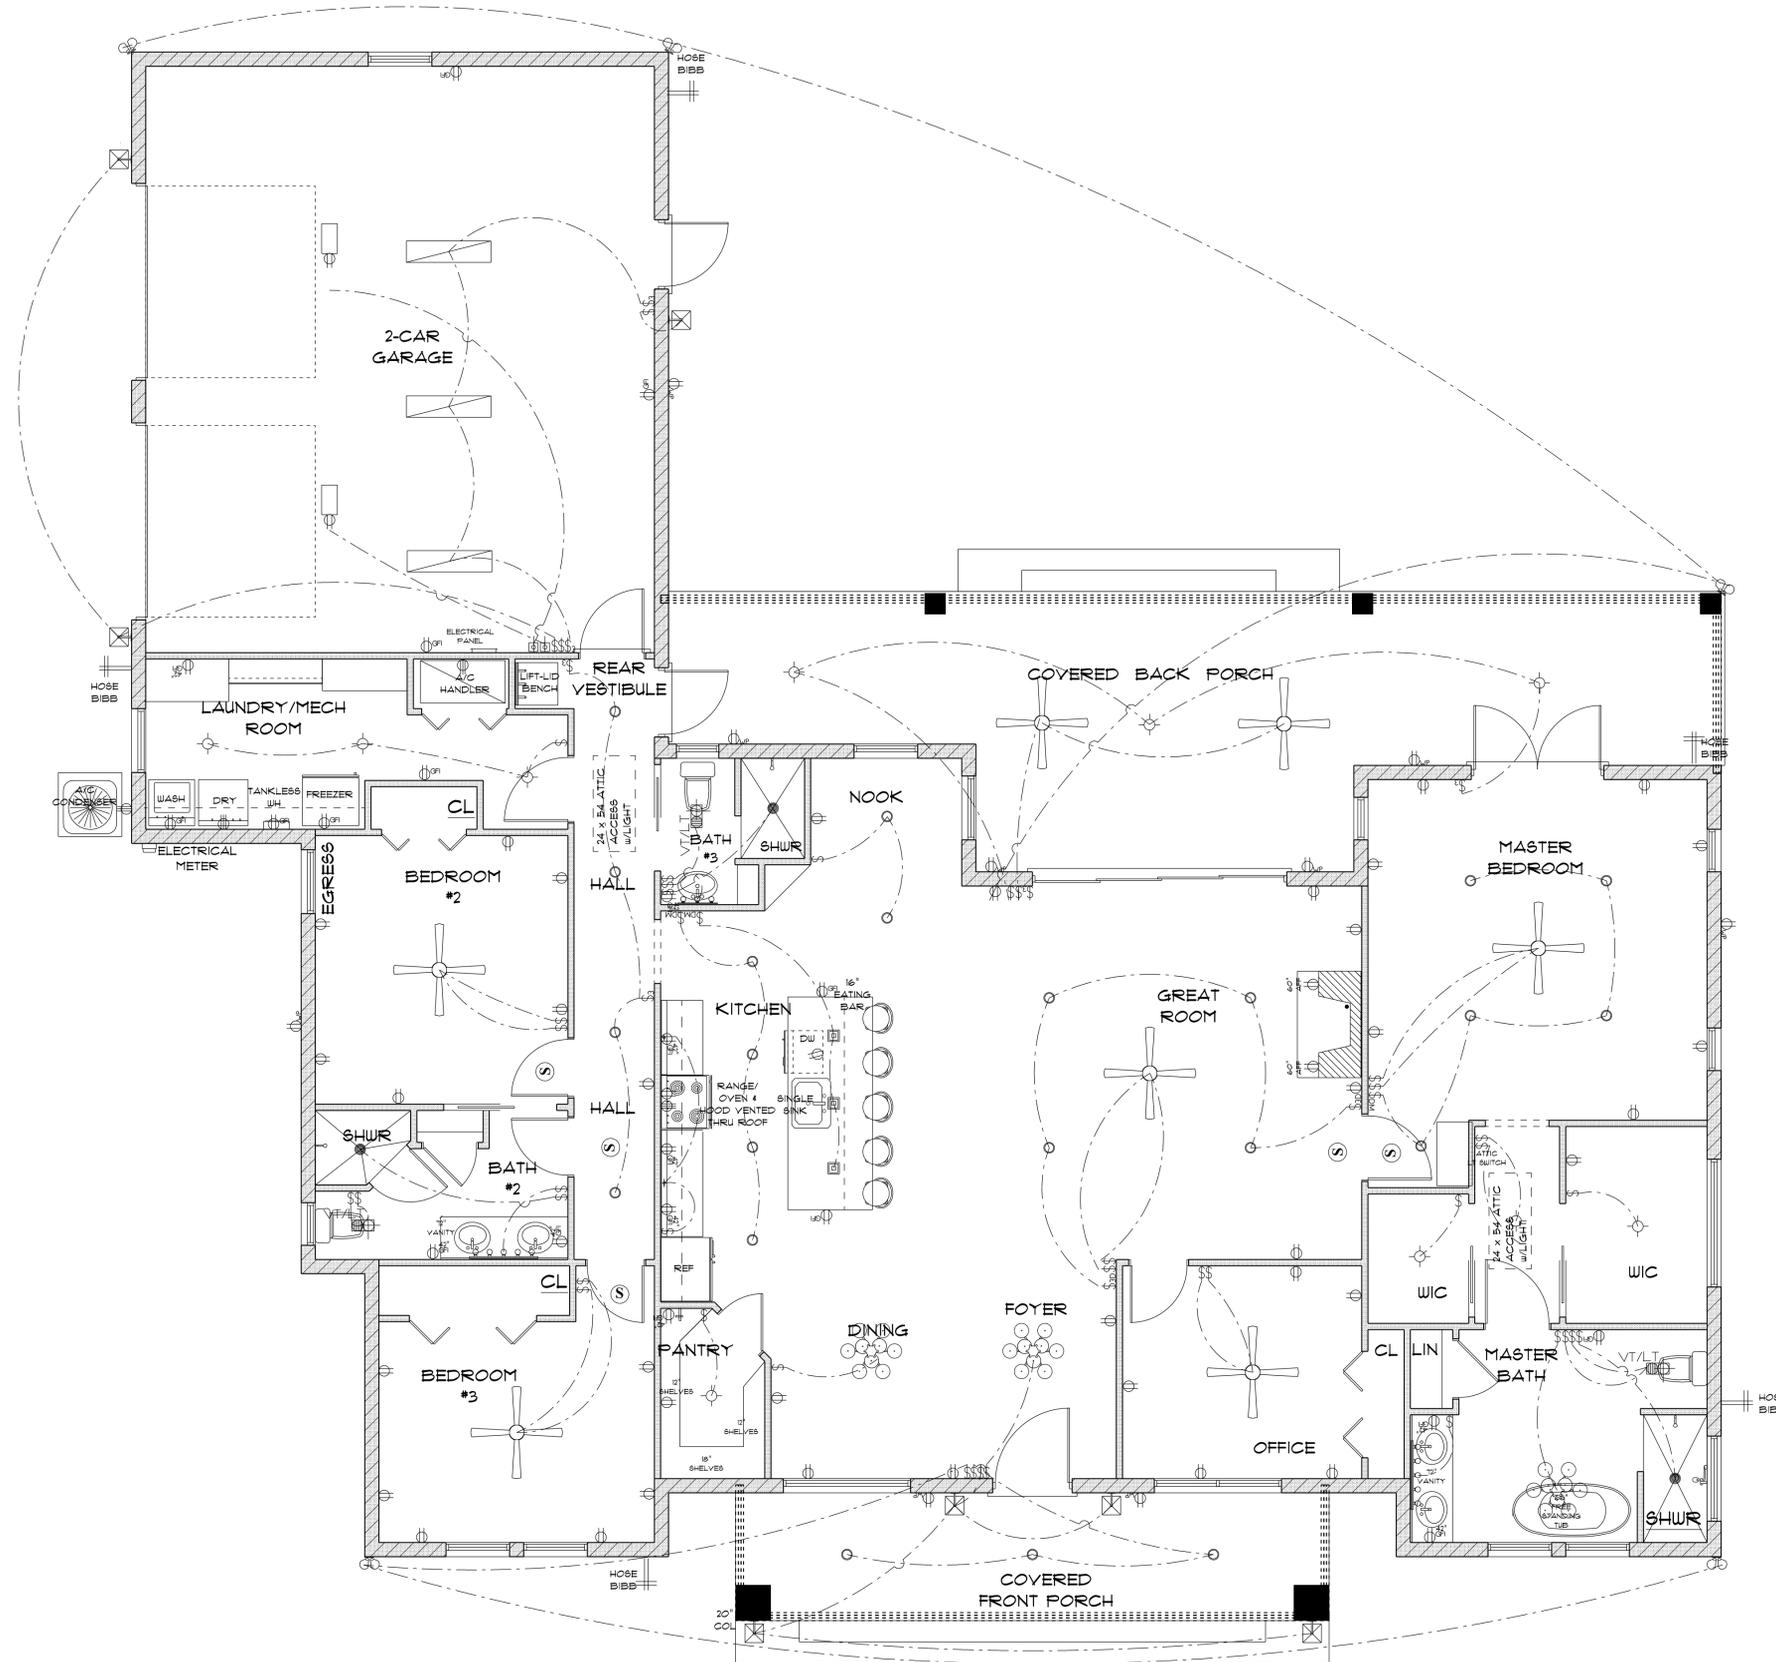

ELECTRICAL LEGEND		
ELECTRICAL	COUNT	SYMBOL
arts and craft exterior light	7	(Symbol)
automatic garage dr opener	2	(Symbol)
ceiling fan globe O1	7	(Symbol)
ceiling light 15	3	(Symbol)
dimmer switch	3	(Symbol)
dimmer switch 3-way	2	(Symbol)
electrical panel	1	(Symbol)
fluorescent light 1 x 4	3	(Symbol)
garage dr opener	2	(Symbol)
light	10	(Symbol)
outlet	41	(Symbol)
outlet 220v	4	(Symbol)
outlet gfi	20	(Symbol)
outlet wp	9	(Symbol)
pendant large	3	(Symbol)
pot light	25	(Symbol)
Smoke Detector	5	(S)
spotlight double	5	(Symbol)
switch	40	(Symbol)
switch 3 way	6	(Symbol)
Under Cab Light Strip	2	(Symbol)
vanity bar light O1	2	(Symbol)
vanity bar light O2	1	(Symbol)
vent light combo	3	(VT/LT)

- ELECTRICAL PLAN NOTES**
- E-1 WIRE ALL APPLIANCES, HVAC UNITS AND OTHER EQUIPMENT PER MANUFACTURER'S SPECIFICATIONS.
 - E-2 ALL INSTALLATIONS SHALL BE PER NATIONAL ELECTRIC CODE.
 - E-3 ALL SMOKE / CARBON MONOXIDE DETECTORS SHALL BE 120V W/BATTERY BACKUP OF THE PHOTOELECTRIC TYPE AND SHALL BE INTERLOCKED TOGETHER. INSTALL INSIDE AND NEAR ALL BEDROOMS AS PER CODE.
 - E-4 TELEPHONE, TELEVISION AND OTHER LOW VOLTAGE DEVICES OR OUTLETS SHALL BE AS PER THE OWNER'S DIRECTION AND IN ACCORDANCE WITH APPLICABLE SECTIONS OF NATIONAL ELCT. CODE LATEST EDITION.
 - E-5 ELECTRICAL CONTRACTOR SHALL BE RESPONSIBLE FOR THE DESIGN AND SIZING OF ELECTRICAL SERVICE AND CIRCUITS.
 - E-6 ENTRY OF SERVICE UNDERGROUND OR OVERHEAD) IS TO BE DETERMINED BY THE POWER COMPANY.
 - E-7 ALL BEDROOM RECEPTALS ARE TO BE AFCI (ARC FAULT CIRCUIT INTERRUPT)
 - E-8 75% OF ALL PERMANENT LIGHTS TO BE ENERGY EFFICIENT.

* ELECTRIC PLAN *

SCALE : 1/4" = 1'-0"

NEW RESIDENCE
for
CASSANDRA & MAURICE SPATES
LAKE CITY, FLORIDA

Teena M. Ruffo
2925 6th St. 41
Lake City, Florida, 32025
Cell: (386) 861-1191
Email: teenaruffo@gmail.com

PRINTED DATE:
Wednesday, October 15, 2025

DRAWN BY: Teena M. Ruffo CHECKED BY: _____
BUILDING CONTRACTOR

FINAL DATE: _____

JOB NUMBER: _____

DRAWING NUMBER
A-6
OF 6 SHEETS