

## US COLD STORAGE


PHASE III EXPANSION LAKE CITY, FLORIDA




LOCATION MAP



VICINITY MAP

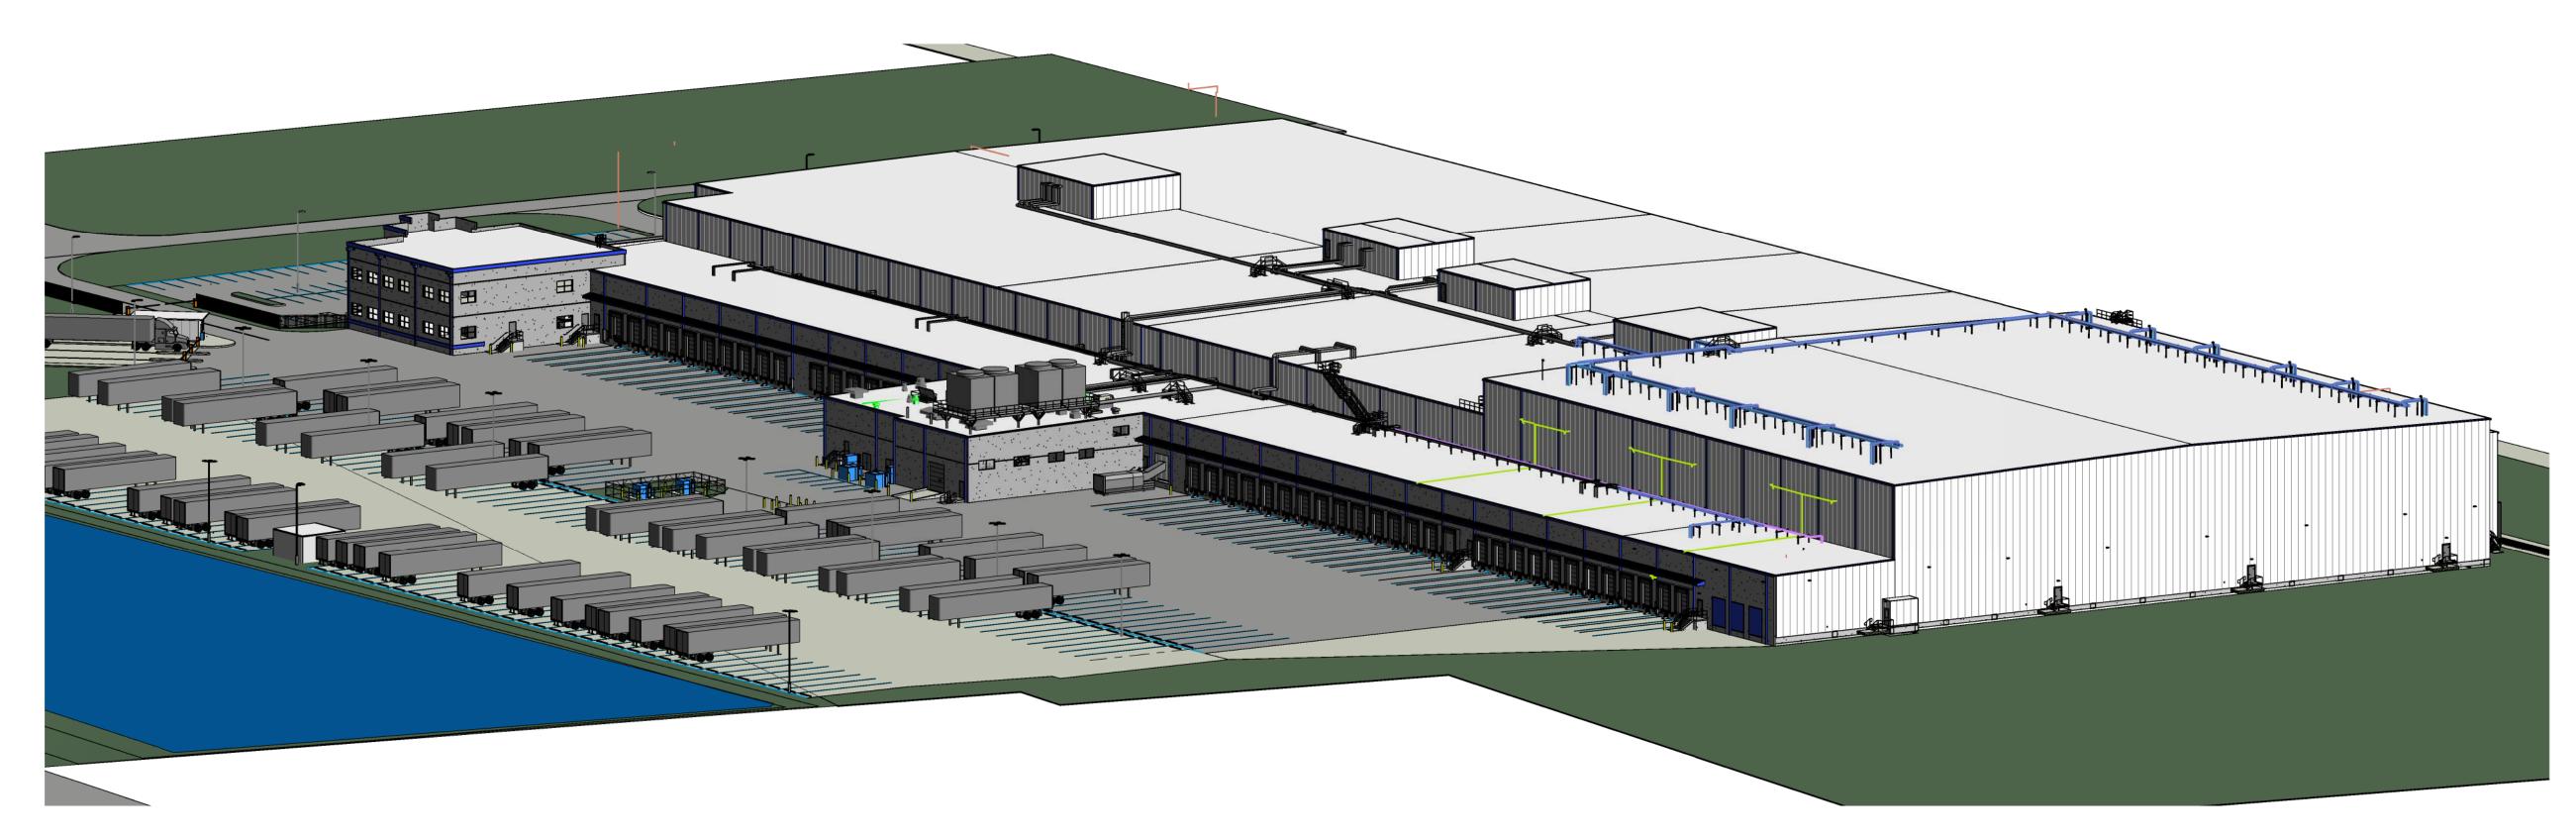



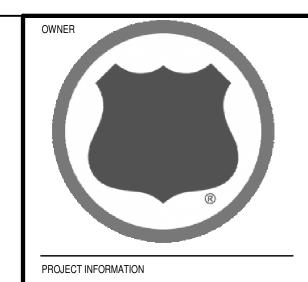

**US COLD STORAGE** PHASE III EXPANSION LAKE CITY, FLORIDA

stellar
TAKING SOLUTIONS FURTHER

OPERATING AS:
THE STELLAR GROUP
2900 HARTLEY ROAD, JACKSONVILLE, FL. 32257 (904) 260-2900
WWW.STELLAR.NET
FLORIDA ARCHITECTURAL LICENSE NO. AR0013370
FLORIDA ENGINEERING LICENSE NO. CA5930



Tanya Frantzen Tillett 2023.05.30 11:14:04-04'00'

The Stellar Group, Inc.
All rights reserved. No part of this work may be used, reproduced, distributed, displayed, or otherwise communicated in any form or by any means without the prior written consent of The Stellar Group, Inc.

EVISIONS					
NO.	DESCRIPTION	DATE			
С	PERMIT ISSUE	05/26/2023			
В	DESIGN DEVELOPMENT 2	04/03/2023			
Α	DESIGN DEVELOPMENT 1	03/06/2023			
$\perp$					
$\rightarrow$					
_					
_					
+					
-					
-					
-		-			
+					
+					
+					
+					
$\dashv$					
+					
+					
$\dashv$					
$\dashv$					
-+		+			

DESIGNED BY:

PROJECT NUMBER:

PRINT IN COLOR

	SHEET INDEX			
SHEET NUMBER	9			
00. GENER	AL		04. CIVIL	
G0001	COVER SHEET		C0001	COVER
G0002	SHEET INDEX		C1001	OVERA
G0004	BUILDING CODE ANALYSIS AND PROJECT INFORMATION		C5001	CIVIL G
G1101	OVERALL FIRST FLOOR LIFE SAFETY PLAN		CG1001	OVERA
GE1101	FIRST AND SECOND FLOOR ENVIRONMENTAL PLANS		CG5001	GRADIN
G5021	PARTITION TYPES		CJ1001	OVERA
G5031	ACCESSIBLE DETAILS		CK1001	OVERAI
G5032	ACCESSIBLE DETAILS		CU1001	OVERA
G9001	3D PERSPECTIVE VIEWS AND RENDERINGS			_

SHEET INDEX		SHEET INDEX		
SHEET UMBER	SHEET NAME	SHEET NUMBER	SHEET NAME	
. CIVIL		06. STRUC	TURAL	
C0001	COVER SHEET	S0001	STRUCTURAL GENERAL NOTES & INSPECTION SCHEDULE	
C1001	OVERALL CIVIL GEOMETRY PLAN	S1000	OVERALL FOUNDATION PLAN	
C5001	CIVIL GEOMETRY DETAIL	S1010	PARTIAL FOUNDATION PLAN - AREA 1	
CG1001	OVERALL GRADING AND DRAINAGE PLAN	S1101	OVERALL SLAB PLAN	
CG5001	GRADING AND DRAINAGE DETAILS	S1111	PARTIAL SLAB PLAN - AREA 1 & 3	
CJ1001	OVERALL EROSION AND SEDIMENT CONTROL PLAN	S1201	OVERALL 2ND FLOOR FRAMING PLAN - AREA 2	
CK1001	OVERALL DRAINAGE MAP	S1401	OVERALL ROOF FRAMING PLAN	
CU1001	OVERALL CIVIL UTILTY PLAN	S1411	PARTIAL ROOF FRAMING PLAN - AREA 1	
		S2001	STRUCTURAL FRAMING ELEVATIONS	
		S2002	STRUCTURAL TILT-UP ELEVATIONS & DETAILS	
		S4001	VESTIBULE PLANS AND STRUCTURAL ELEVATIONS	

S4211 EMPTY PALLET STORAGE FRAMING PLANS

S4212 MAINTENANCE CATWALK FRAMING PLAN - AREA 1
S4601 STAIR PLANS AND SECTIONS - AREA 1
S5001 TYPICAL CONCRETE DETAILS

S5003 STRUCTURAL TYPICAL STEEL DETAILS
S5005 BASE PLATE, ANCHOR BOLTS AND PIER DETAILS

S5011 STRUCTURAL FOUNDATION DETAILS S5012 STRUCTURAL FOUNDATION DETAILS

S5031 STRUCTURAL BRACING DETAILS
S5041 STRUCTURAL ROOF FRAMING DETAILS

S6001 ROOF DECK ATTACHMENT PLAN
S6002 ROOF JOIST UPLIFT DIAGRAM

	SHEET INDEX
SHEET NUMBER	SHEET NAME
07. ARCHIT	ECTURE
AS1001	ARCHITECTURAL SITE PLAN
AD1101	OVERALL FIRST FLOOR DEMOLITION PLAN
AD1111	PARTIAL FIRST FLOOR DEMOLITION PLAN - AREA 1
AD1112	PARTIAL FIRST FLOOR DEMOLITION ELEVATIONS - ARI
AJ1111	PARTIAL SLAB PLAN - AREA 1
A1101	OVERALL FIRST FLOOR PLAN
A1111	PARTIAL FIRST FLOOR PLAN - AREA 1
A1112	PARTIAL FIRST FLOOR EQUIPMENT PLAN - AREA 1
A1113	PARTIAL FIRST FLOOR CATWALK PLAN - AREA 1
A1401	OVERALL ROOF PLAN
A1411	PARTIAL ROOF PLAN - AREA 1
A1601	OVERALL FIRST FLOOR REFLECTED CEILING PLAN
A1611	PARTIAL FIRST FLOOR REFLECTED CEILING PLAN - AR
A2001	OVERALL EXTERIOR ELEVATIONS
A2011	PARTIAL EXTERIOR ELEVATIONS
A3001	OVERALL BUILDING SECTIONS
A3002	PARTIAL BUILDING SECTIONS
A3021	WALL SECTIONS
A3022	WALL SECTIONS
A3023	WALL SECTIONS
A4111	ENLARGED BREAK ROOM AND USDA PLANS - AREA 2
A4112	ENLARGED BREAK ROOM AND USDA SECTIONS - AREA
A4113	ENLARGED PAVILLION PLANS AND ELEVATIONS - AREA
A4114	GUARD HOUSE
A4501	RAIL DOCK PALLET RACK
A4502	DOCK PLANS
A4601	ENLARGED RESTROOM PLANS AND INTERIOR ELEVAT
A4611	ENLARGED STAIR PLANS AND SECTIONS
A4612	ENLARGED STAIR PLANS AND SECTIONS
A4613	ENLARGED STAIR PLANS AND SECTIONS
A4614	ENLARGED STAIR PLANS AND SECTIONS
A5011	WALL DETAILS
A5021	CEILING DETAILS
A5031	ROOF DETAILS
A5041	STAIR DETAILS
A5042	STAIR DETAILS
A5052	DOCK DETAILS
A5053	CURB DETAILS
A5061	BOLLARD AND GUARD DETAILS
A5901	PENETRATION DETAILS
A6001	ROOM FINISH SCHEDULE
A7001	DOOR AND WINDOW SCHEDULE
A7002	DOOR AND WINDOW DETAILS
A7003	DOOR AND WINDOW DETAILS


		T
	SHEET NUMBER	SHEET NAME
	11. PLUMB	BING
	P0001	PLUMBING LEGEND AND NOTES
	P1101	OVERALL FIRST FLOOR PLUMBING PLAN
AREA 1	P1111	PARTIAL FIRST FLOOR PLUMBING PLAN - AREA 1
	P1121	PARTIAL FIRST FLOOR PLUMBING PLAN - AREA 2
	P1221	PARTIAL SECOND FLOOR PLUMBING PLAN - AREA 2
	P1311	PARTIAL ROOF PLUMBING PLAN - AREA 1
	PS1100	PLUMBING - UTILITY SITE PLAN
	P4121	ENLARGED FIRST FLOOR PLUMBING / UTILITY PLANS - AREA 2
	P4221	ENLARGED SECOND FLOOR PLUMBING / UTILITY PLANS - AREA 2
	P5001	PLUMBING - UTILITY DETAILS
	P5002	PLUMBING - UTILITY DETAILS
AREA 1	P6001	PLUMBING - UTILITY SCHEDULES
	P6002	PLUMBING - UTILITY SCHEDULES
	P7001	PLUMBING RISER DIAGRAMS
	P7002	COMPRESSED AIR FLOW DIAGRAM

SHEET INDEX

		SHEET NUMBER	
		13. MECHA	
		M0001	MECHA
		M1101	OVERAL
		M1121	PARTIA
		M1221	PARTIA
<u>)</u>		M1401	OVERAL
		M1421	PARTIA
		MD1121	PARTIA
IS - AREA 2		MD1221	PARTIA
LANS - AREA 2		MD1421	PARTIA
		M5001	MECHA
		M6001	MECHA
		M7001	MECHAI
	•		

SHEET INDEX		SHEET INDEX		
SHEET NAME	SHEET NUMBER	SHEET NAME		
	14. ELECTF	RICAL		
	E0001	ELECTRICAL GENERAL NOTES, SYMBOLS AND ABBREVIATIONS		
CAL LEGEND, NOTES & SCHEDULES	ED1001	ELECTRICAL DEMOLITION SITE PLAN		
FIRST FLOOR MECHANICAL PLAN	ED1101	OVERALL FIRST FLOOR DEMOLITION PLAN		
FIRST FLOOR MECHANICAL PLAN – AREA 2	E1101	FIRST AND SECOND FLOOR ENVIRONMENTAL PLANS		
SECOND FLOOR MECHANICAL PLAN – AREA 2	ES1001	ELECTRICAL SITE PLAN		
ROOF MECHANICAL PLAN	EL1111	PARTIAL FIRST FLOOR LIGHTING PLAN - AREA 1		
ROOF MECHANICAL PLAN - AREA 2	EP1101	OVERALL FIRST FLOOR POWER PLAN		
FIRST FLOOR MECHANICAL DEMOLITION PLAN – AREA 2	EP1111	PARTIAL FIRST FLOOR POWER PLAN - AREA 1		
SECOND FLOOR MECHANICAL DEMOLITION PLAN – AREA 2	EP1401	OVERALL ROOF POWER PLAN		
ROOF MECHANICAL DEMOLITION PLAN – AREA 2	E4120	ENLARGED FIRST FLOOR LIGHTING & POWER PLAN – AREA 2 AND		
CAL DETAILS		ADJACENT AREAS		
CAL SCHEDULES	EP4111	ENLARGED FIRST FLOOR POWER PLAN – AREA 1		
CAL CONTROLS	E5001	ELECTRICAL DETAILS		
	E5002	ELECTRICAL DETAILS		
	E6100	ELECTRICAL SINGLE LINE DIAGRAM		
	E6101	PANEL SCHEDULES		
	E6102	PANEL SCHEDULES		

	SHEET INDEX		
	SHEET NUMBER	SHEET NAME	
	18. REFRIC	ERATION	
	R0001	REFRIGERATION COVER SHEET	
	R0002	REFRIGERATION SYMBOLS	
	R1000	REFRIGERATION PLAN PIPE AND EQUIPMENT UNDERGROUND	
	R1110	REFRIGERATION PLAN PIPE AND EQUIPMENT FLOOR OVERALL	
	R1140	REFRIGERATION PLAN PIPE AND EQUIPMENT ROOF OVERALL	
	R4110	REFRIGERATION MACHINE ROOM PIPE & EQUIPMENT FLOOR OVAERALL	
	R5000	REFRIGERATION DETAILS GENERAL	
	R5001	REFRIGERATION DETAILS GENERAL	
	R5010	REFRIGERATION DETAILS GENERAL	
	R5011	REFRIGERATION DETAILS GENERAL	
	R5012	REFRIGERATION DETAILS GENERAL	
	R5013	REFRIGERATION DETAILS GENERAL	
	R5100	REFRIGERATION DETAILS PIPE AND EQUIPMENT	
	R5101	REFRIGERATION DETAILS PIPE AND EQUIPMENT	
	R5103	REFRIGERATION DETAILS PIPE AND EQUIPMENT	
	R5200	REFRIGERATION DETAILS SUPPORTS	
	R5210	REFRIGERATION DETAILS SUPPORTS	
	R5211	REFRIGERATION DETAILS SUPPORTS	
	R5220	REFRIGERATION DETAILS SUPPORTS	
	R5221	REFRIGERATION DETAILS DUCT	
	R5222	REFRIGERATION DETAILS SUPPORTS	
	R5400	REFRIGERATION DETAILS SAFETY	
	R6000	REFRIGERATION SCHEDULES	
	R7000	REFRIGERATION BLOCK FLOW	
	R7001	REFRIGERATION P&ID	

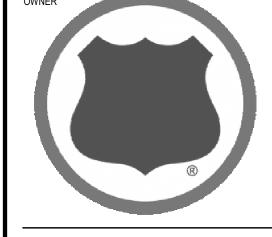

PROJECT INFORMATION

**US COLD STORAGE** PHASE III EXPANSION LAKE CITY, FLORIDA



OPERATING AS: THE STELLAR GROUP 2900 HARTLEY ROAD, JACKSONVILLE, FL. 32257 (904) 260-2900 WWW.STELLAR.NET FLORIDA ARCHITECTURAL LICENSE NO. AR0013370 FLORIDA ENGINEERING LICENSE NO. CA5930



Tanya Frantzen Tillett 2023.05.30 11:14:11-04'00'

CONSULTANT

The Stellar Group, Inc.
All rights reserved. No part of this work may be used, reproduced, distributed, displayed, or otherwise communicated in any form or by any means without the prior written consent of The Stellar Group, Inc.

DESCRIPTION PERMIT ISSUE B DESIGN DEVELOPMENT 2 A DESIGN DEVELOPMENT 1 03/06/2023

03/06/2023

LTW


07366

DATE ISSUED: DESIGNED BY:

REVIEWED BY: A/EOR:


SHEET TITLE


PROJECT NUMBER:

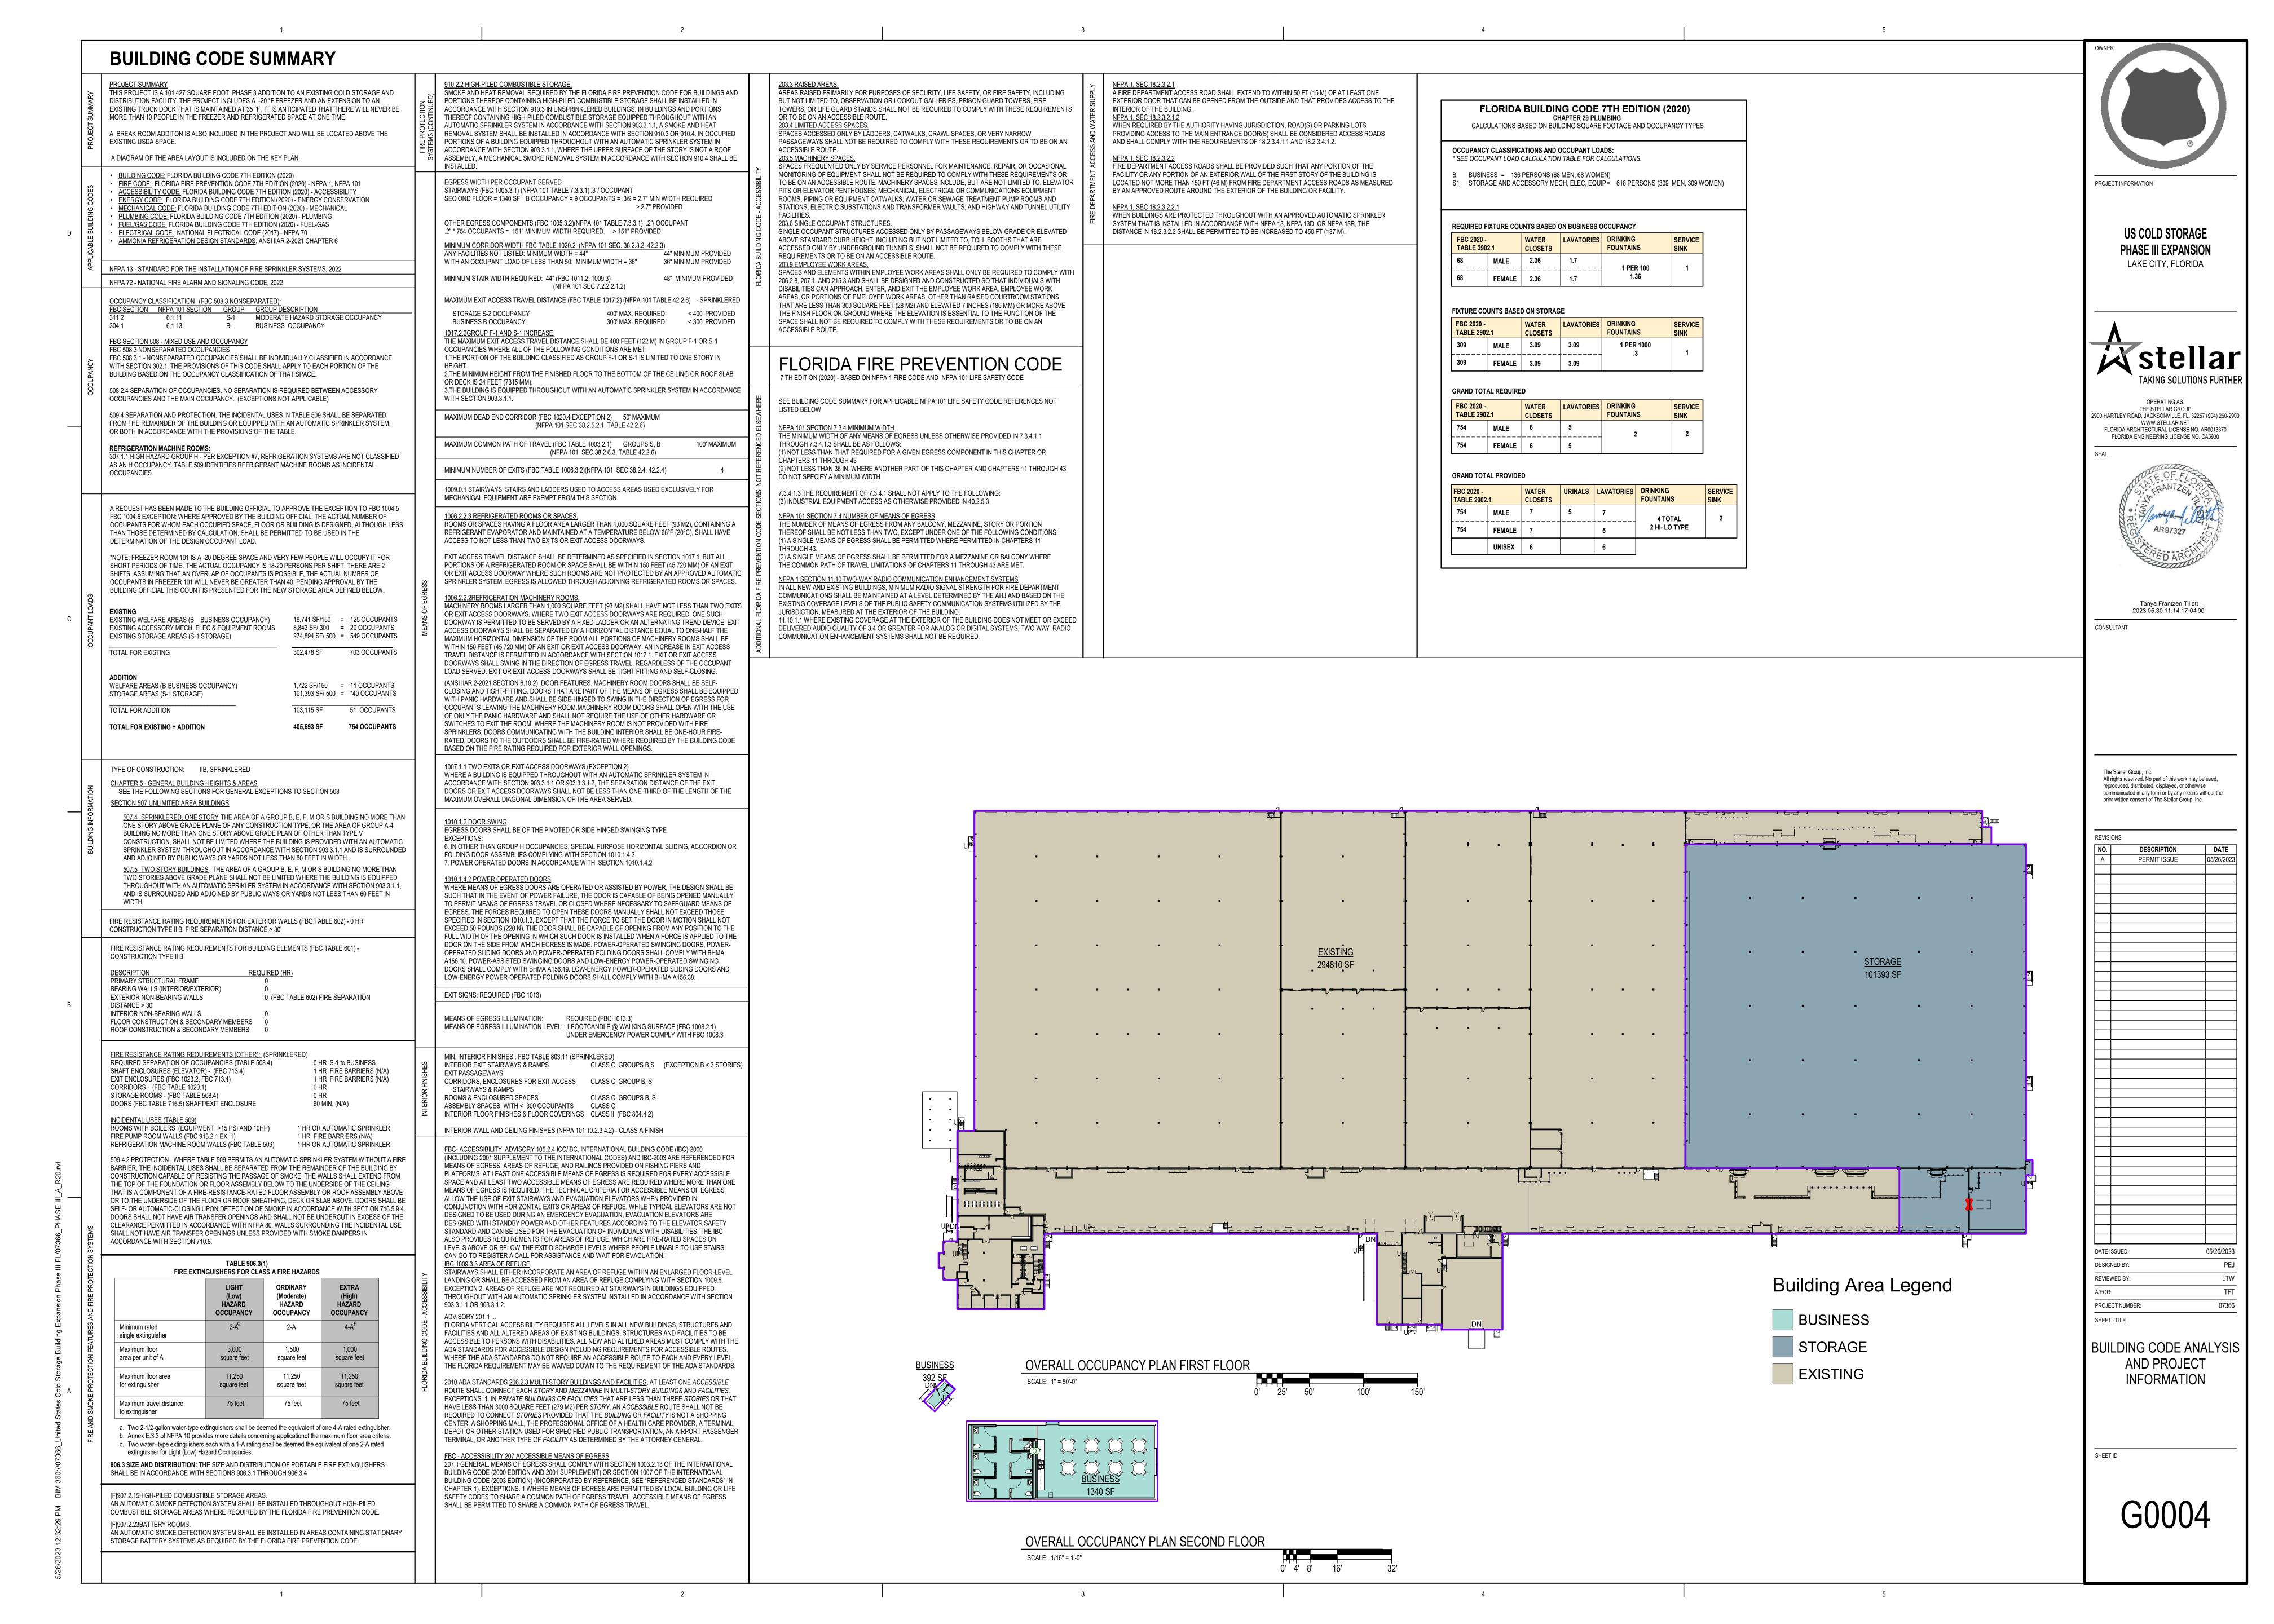



5		EETV I ECEND	OWNER
	e LIFE SA	FETY LEGEND  EXIT SIGNS	
	EXIT 60"	EXIT DOOR EGRESS WIDTH	
	● FE ● FEC	FIRE EXTINGUISHER (16) FIRE EXTINGUISHER CABINET (1)	®
		PATH OF TRAVEL WITH START POINT DIRECTION OF TRAVEL	PROJECT INFORMATION
	XX' NOTES:	PATH OF TRAVEL WITH START POINT	US COLD STORAGE
		AT THE OFFICE & WELFARE AREAS I CABINETS.	PHASE III EXPANSION  LAKE CITY, FLORIDA
	FE ACC  E.W. = 32 32"/0.15 = 21:	MAN ESS  "3 Pers.  MAN ESS  "3 Pers.  MAN ESS  "4 A C C C C C C C C C C C C C C C C C C	TAKING SOLUTIONS FURTHER  OPERATING AS: THE STELLAR GROUP  2000 HARTLEY ROAD, JACKSONNULE, FL. 32257 (904) 200-2000  FLORIDA ANCHITECTURAL USES NO. AR800 13370  FLORIDA PARCHITECTURAL USES NO. AR800 13
AREA 3	EXISTING  AREA 2  10.7 11.6  KEY PL	i i i 17.2 20.5 23  AN	G1101
5	EXISTING	NEW	PRINT IN COLOR




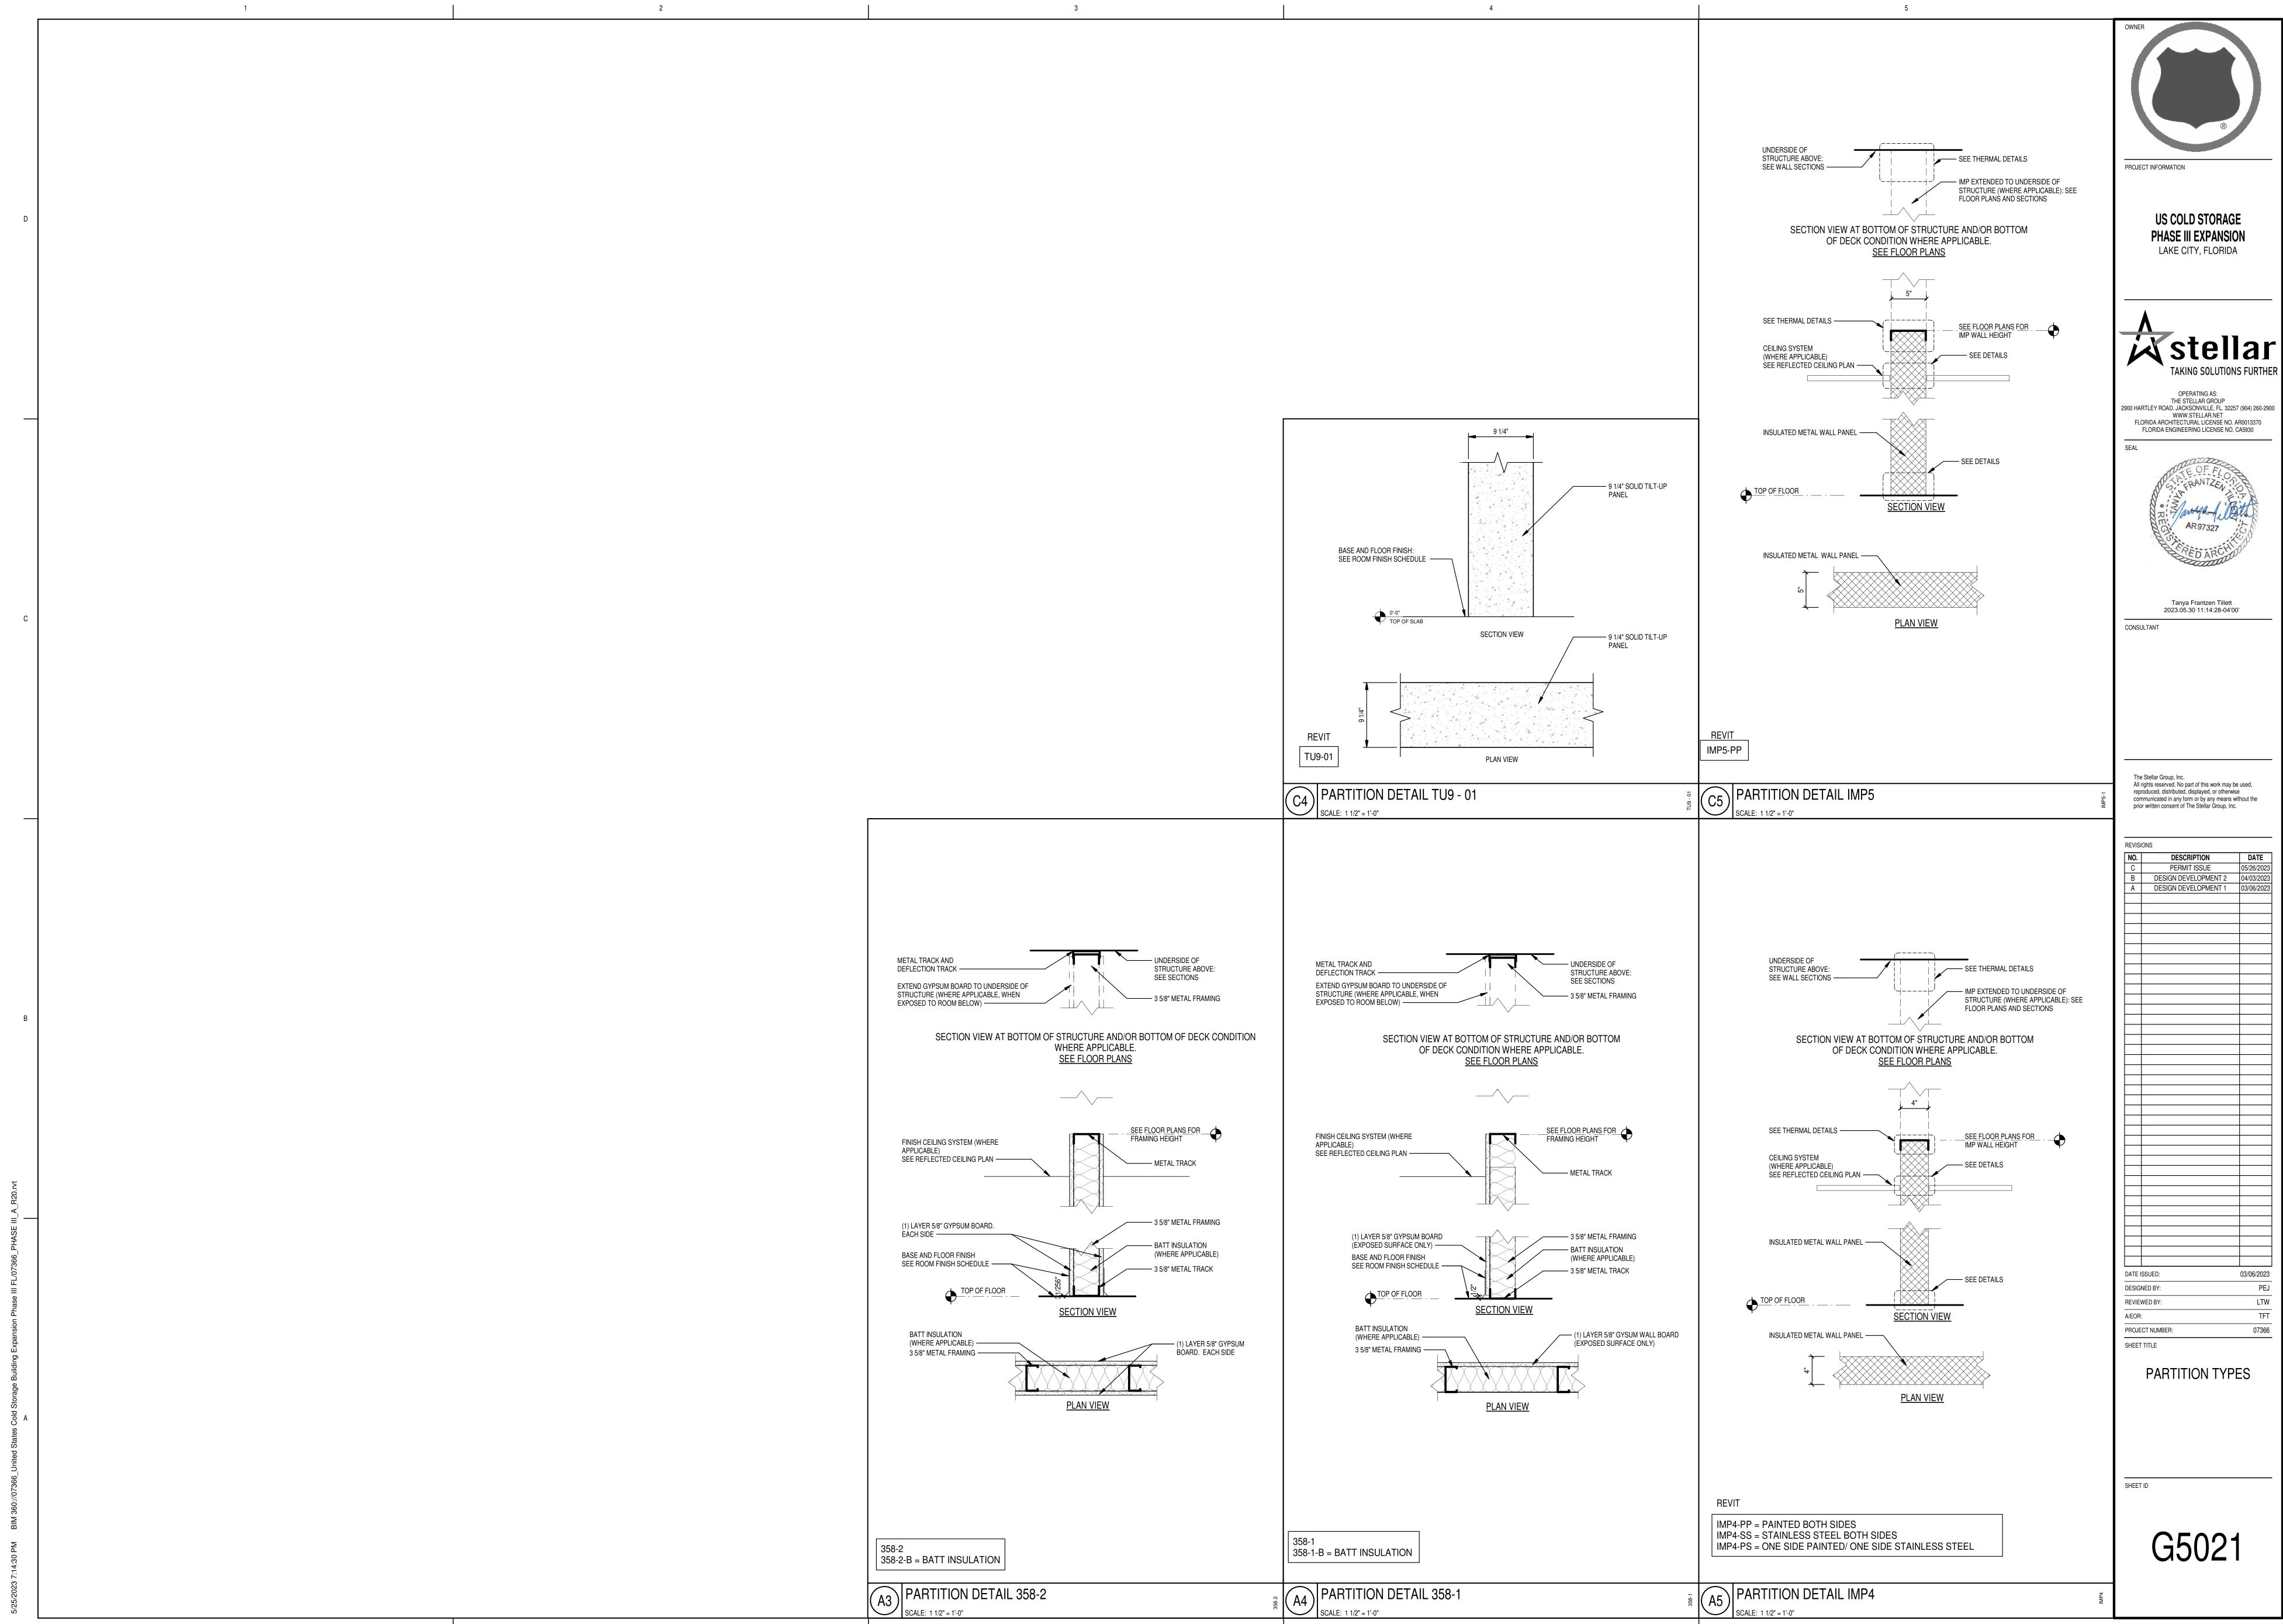

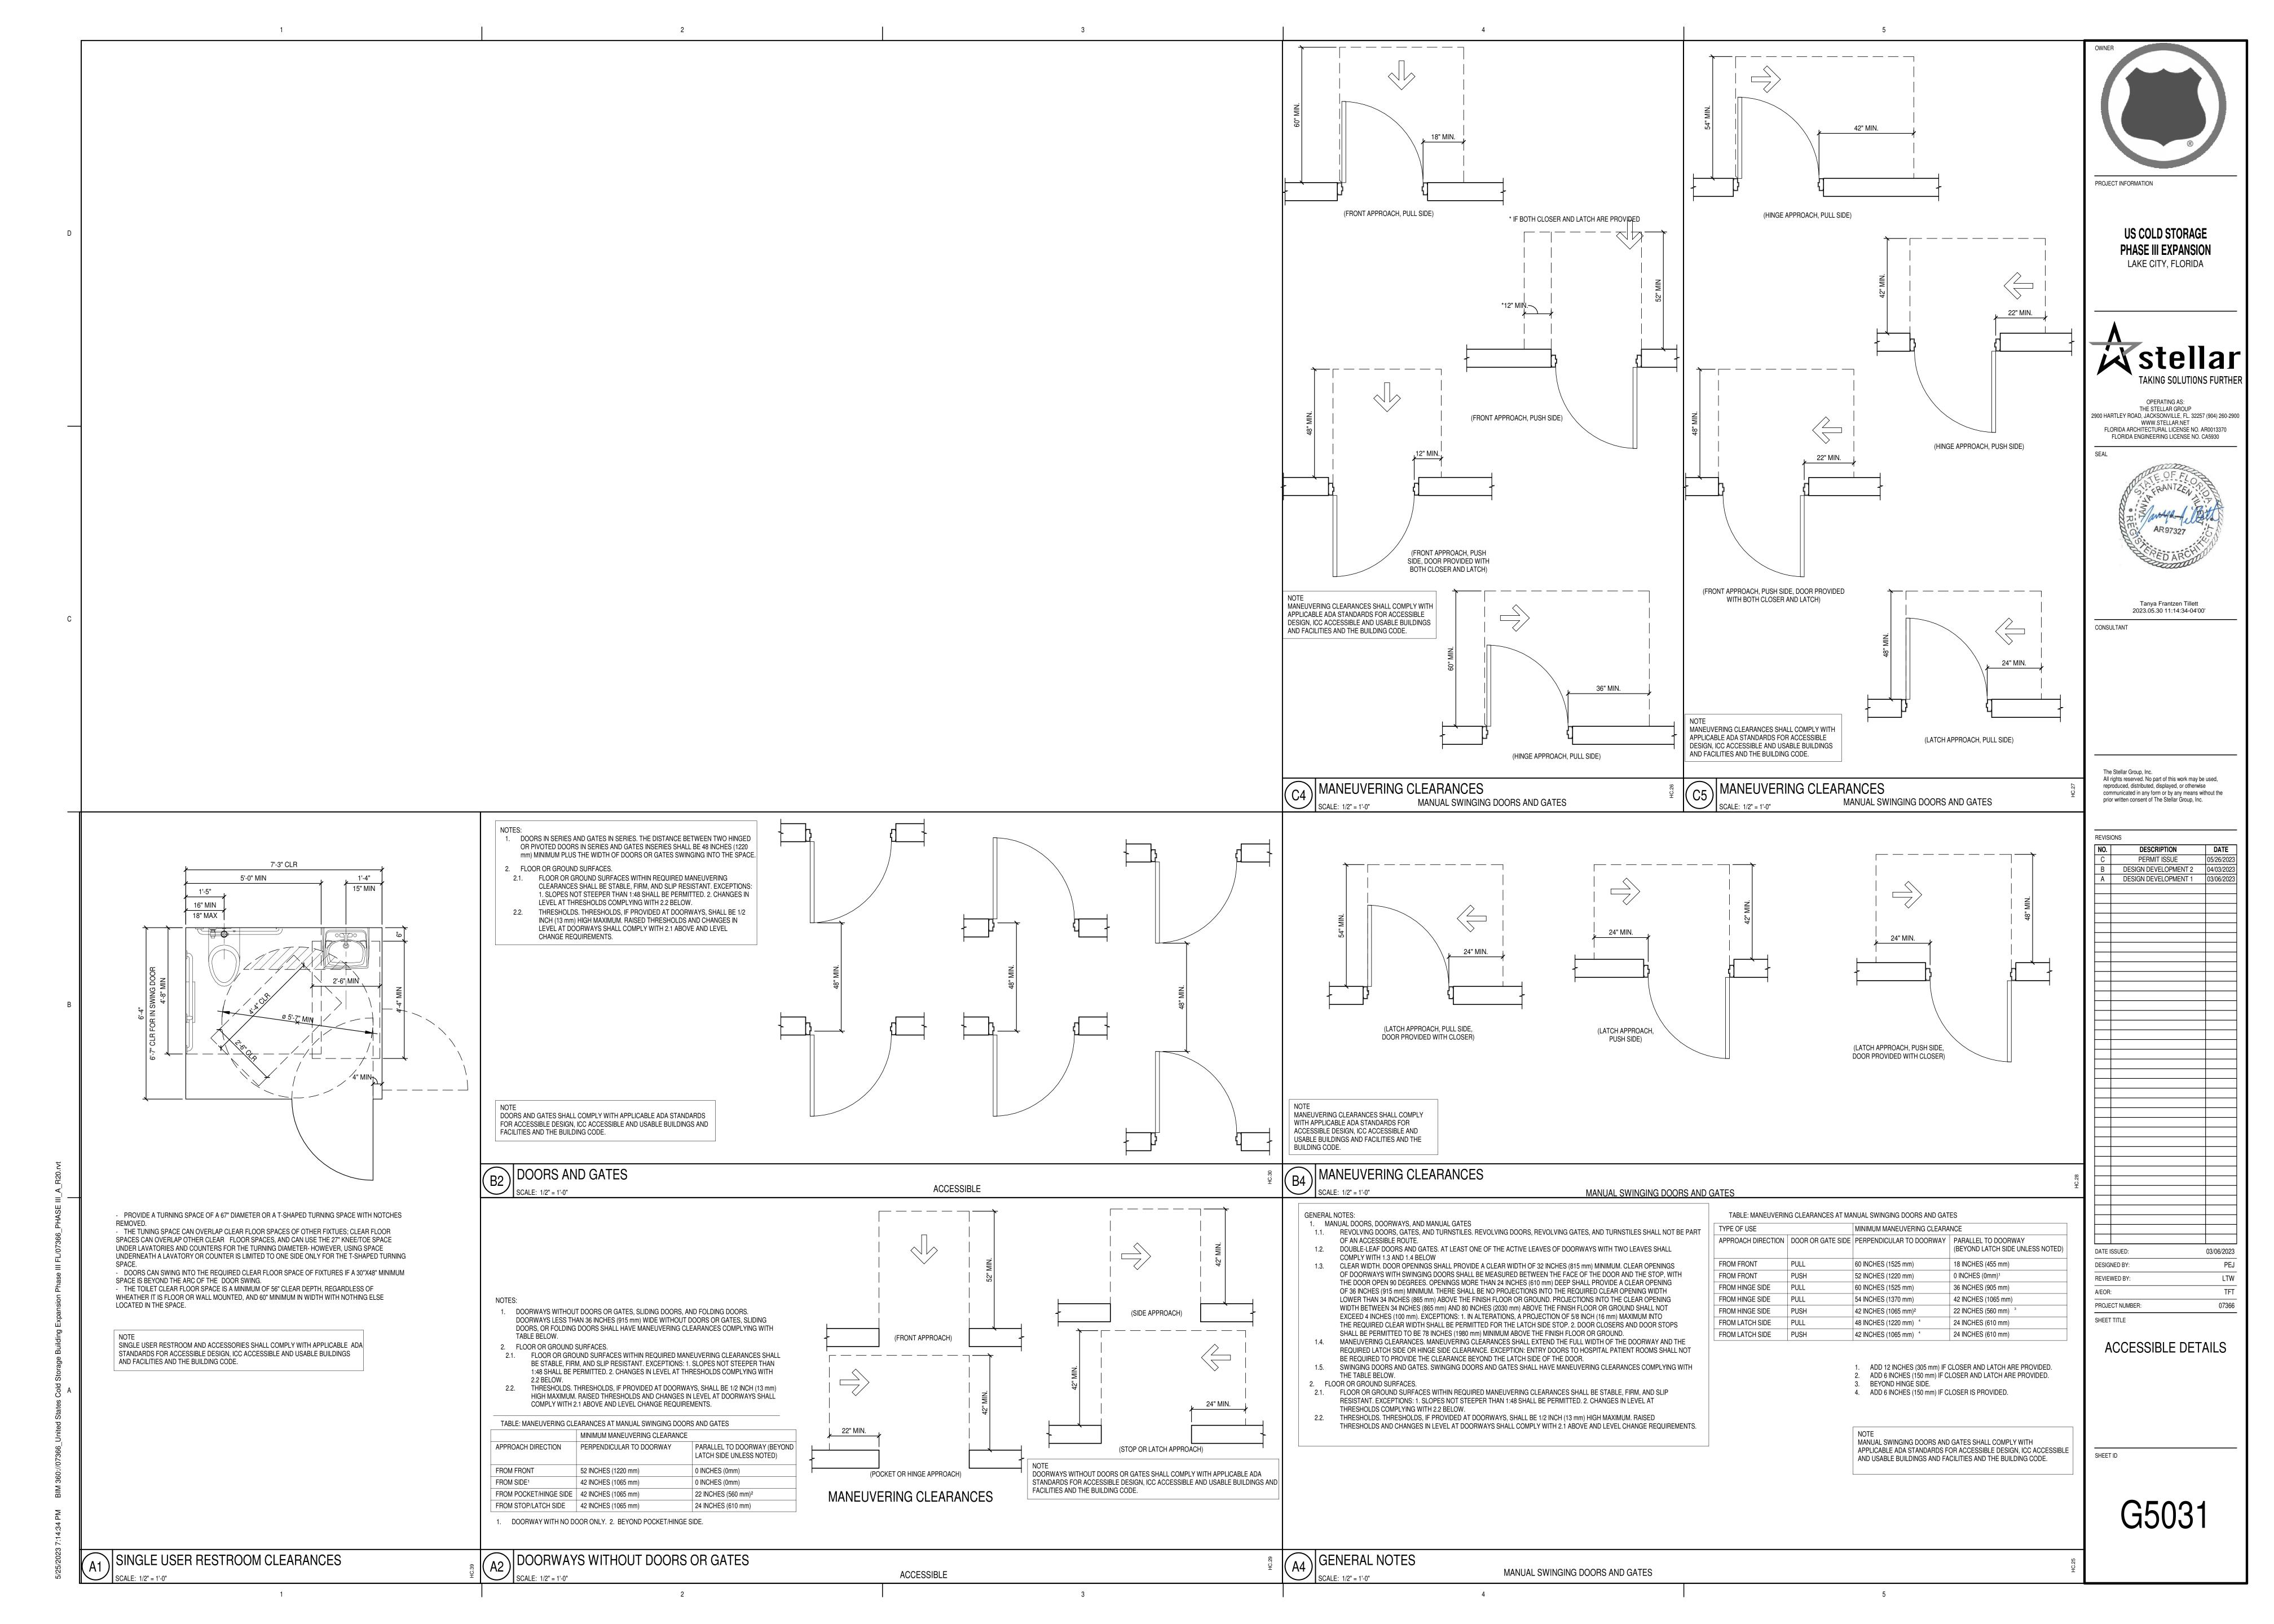

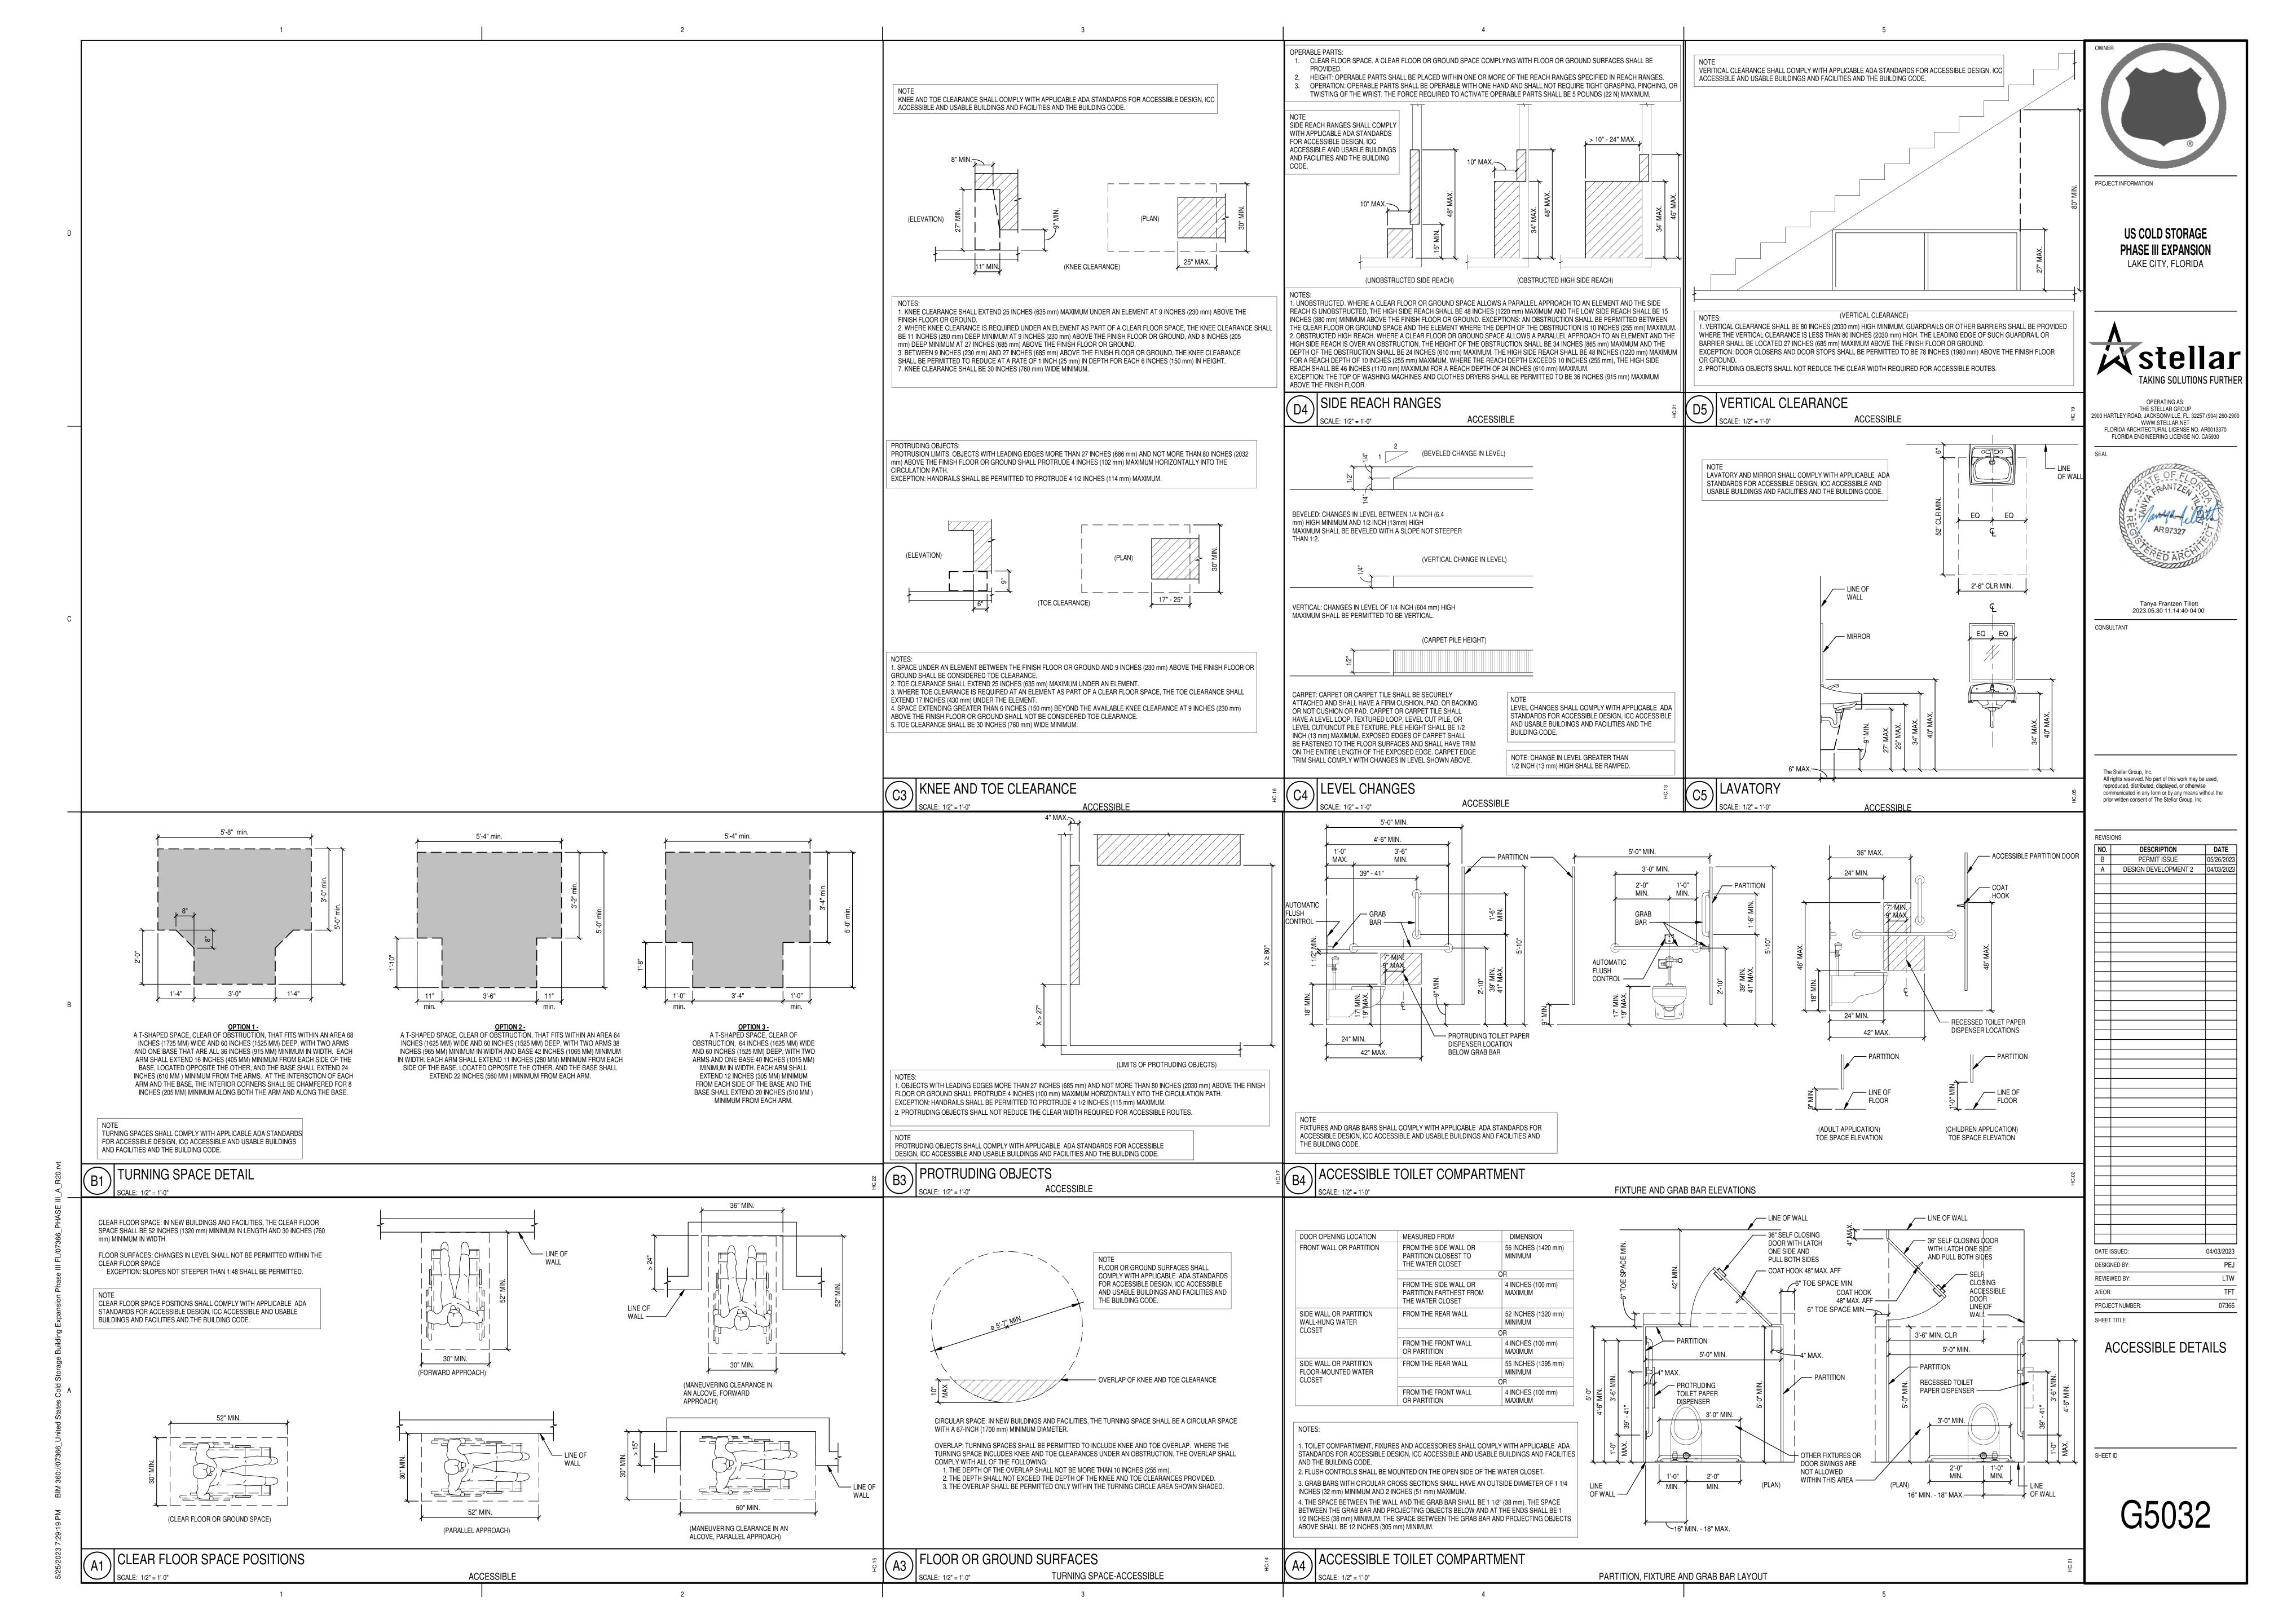

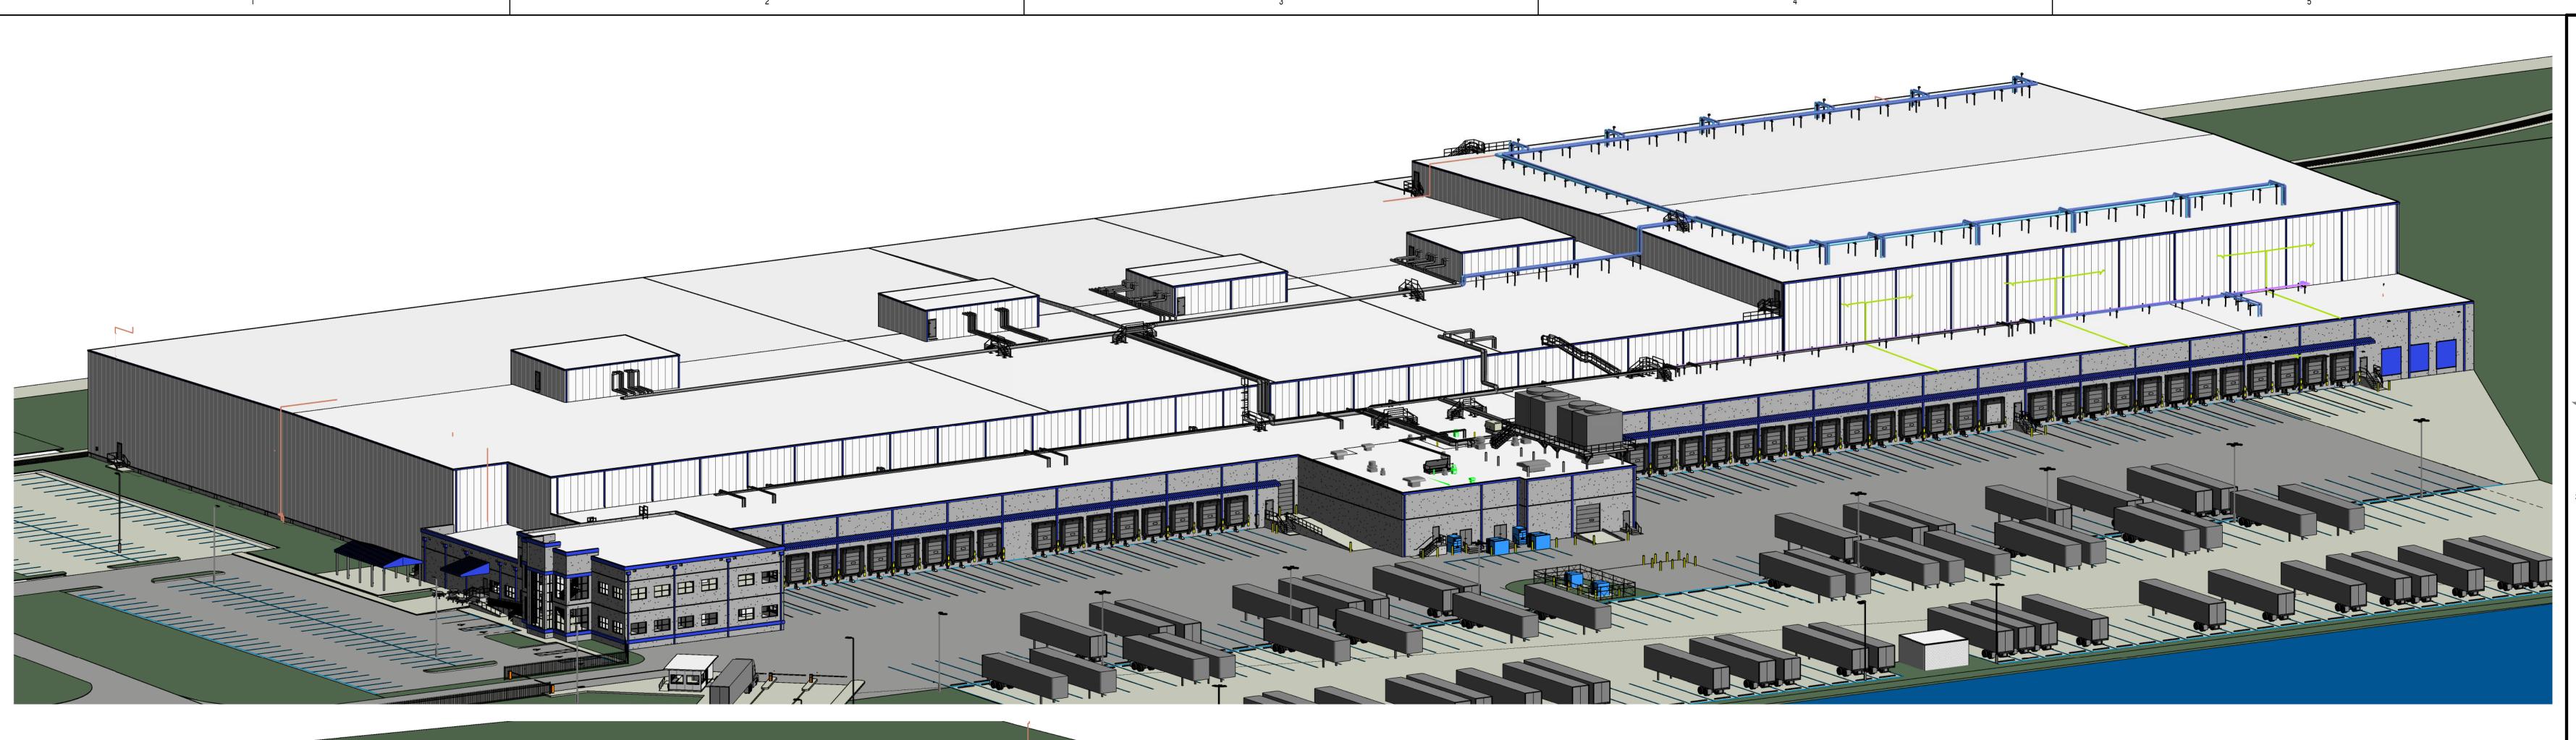

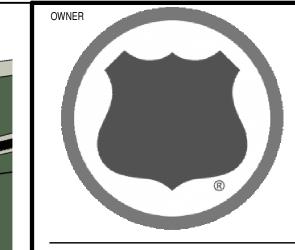

PROJECT INFORMATION

US COLD STORAGE
PHASE III EXPANSION
LAKE CITY, FLORIDA



OPERATING AS:
THE STELLAR GROUP
2900 HARTLEY ROAD, JACKSONVILLE, FL. 32257 (904) 260-2900
WWW.STELLAR.NET
FLORIDA ARCHITECTURAL LICENSE NO. AR0013370
FLORIDA ENGINEERING LICENSE NO. CA5930



Tanya Frantzen Tillett 2023.05.30 11:14:45-04'00'

CONSULTANT

The Stellar Group, Inc.
All rights reserved. No part of this work may be used, reproduced, distributed, displayed, or otherwise communicated in any form or by any means without the prior written consent of The Stellar Group, Inc.

10.	DESCRIPTION	DATE
С	PERMIT ISSUE	05/26/2023
В	DESIGN DEVELOPMENT 2	04/03/2023
Α	DESIGN DEVELOPMENT 1	03/06/2023

DATE ISSUED: 03/06/2023

DESIGNED BY: PEJ

REVIEWED BY: LTW

A/EOR: TFT

PROJECT NUMBER: 07366


SHEET TITLE

3D PERSPECTIVE VIEWS AND RENDERINGS


SHEET I

G900<sup>-</sup>

RINT IN COLOR

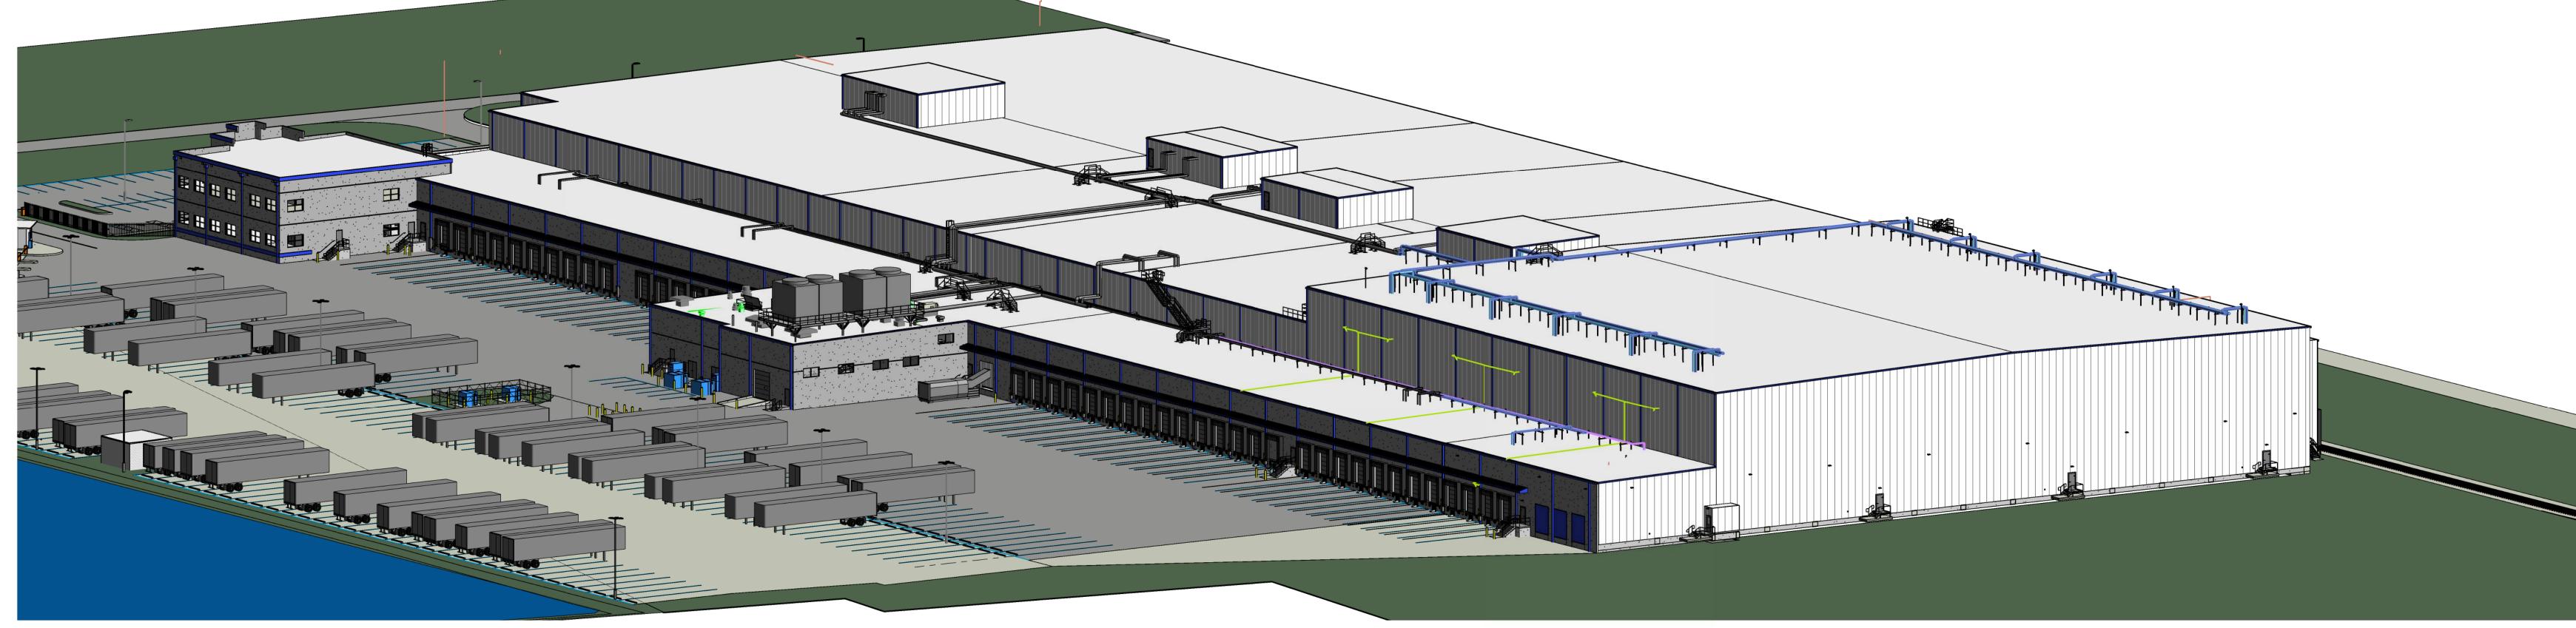



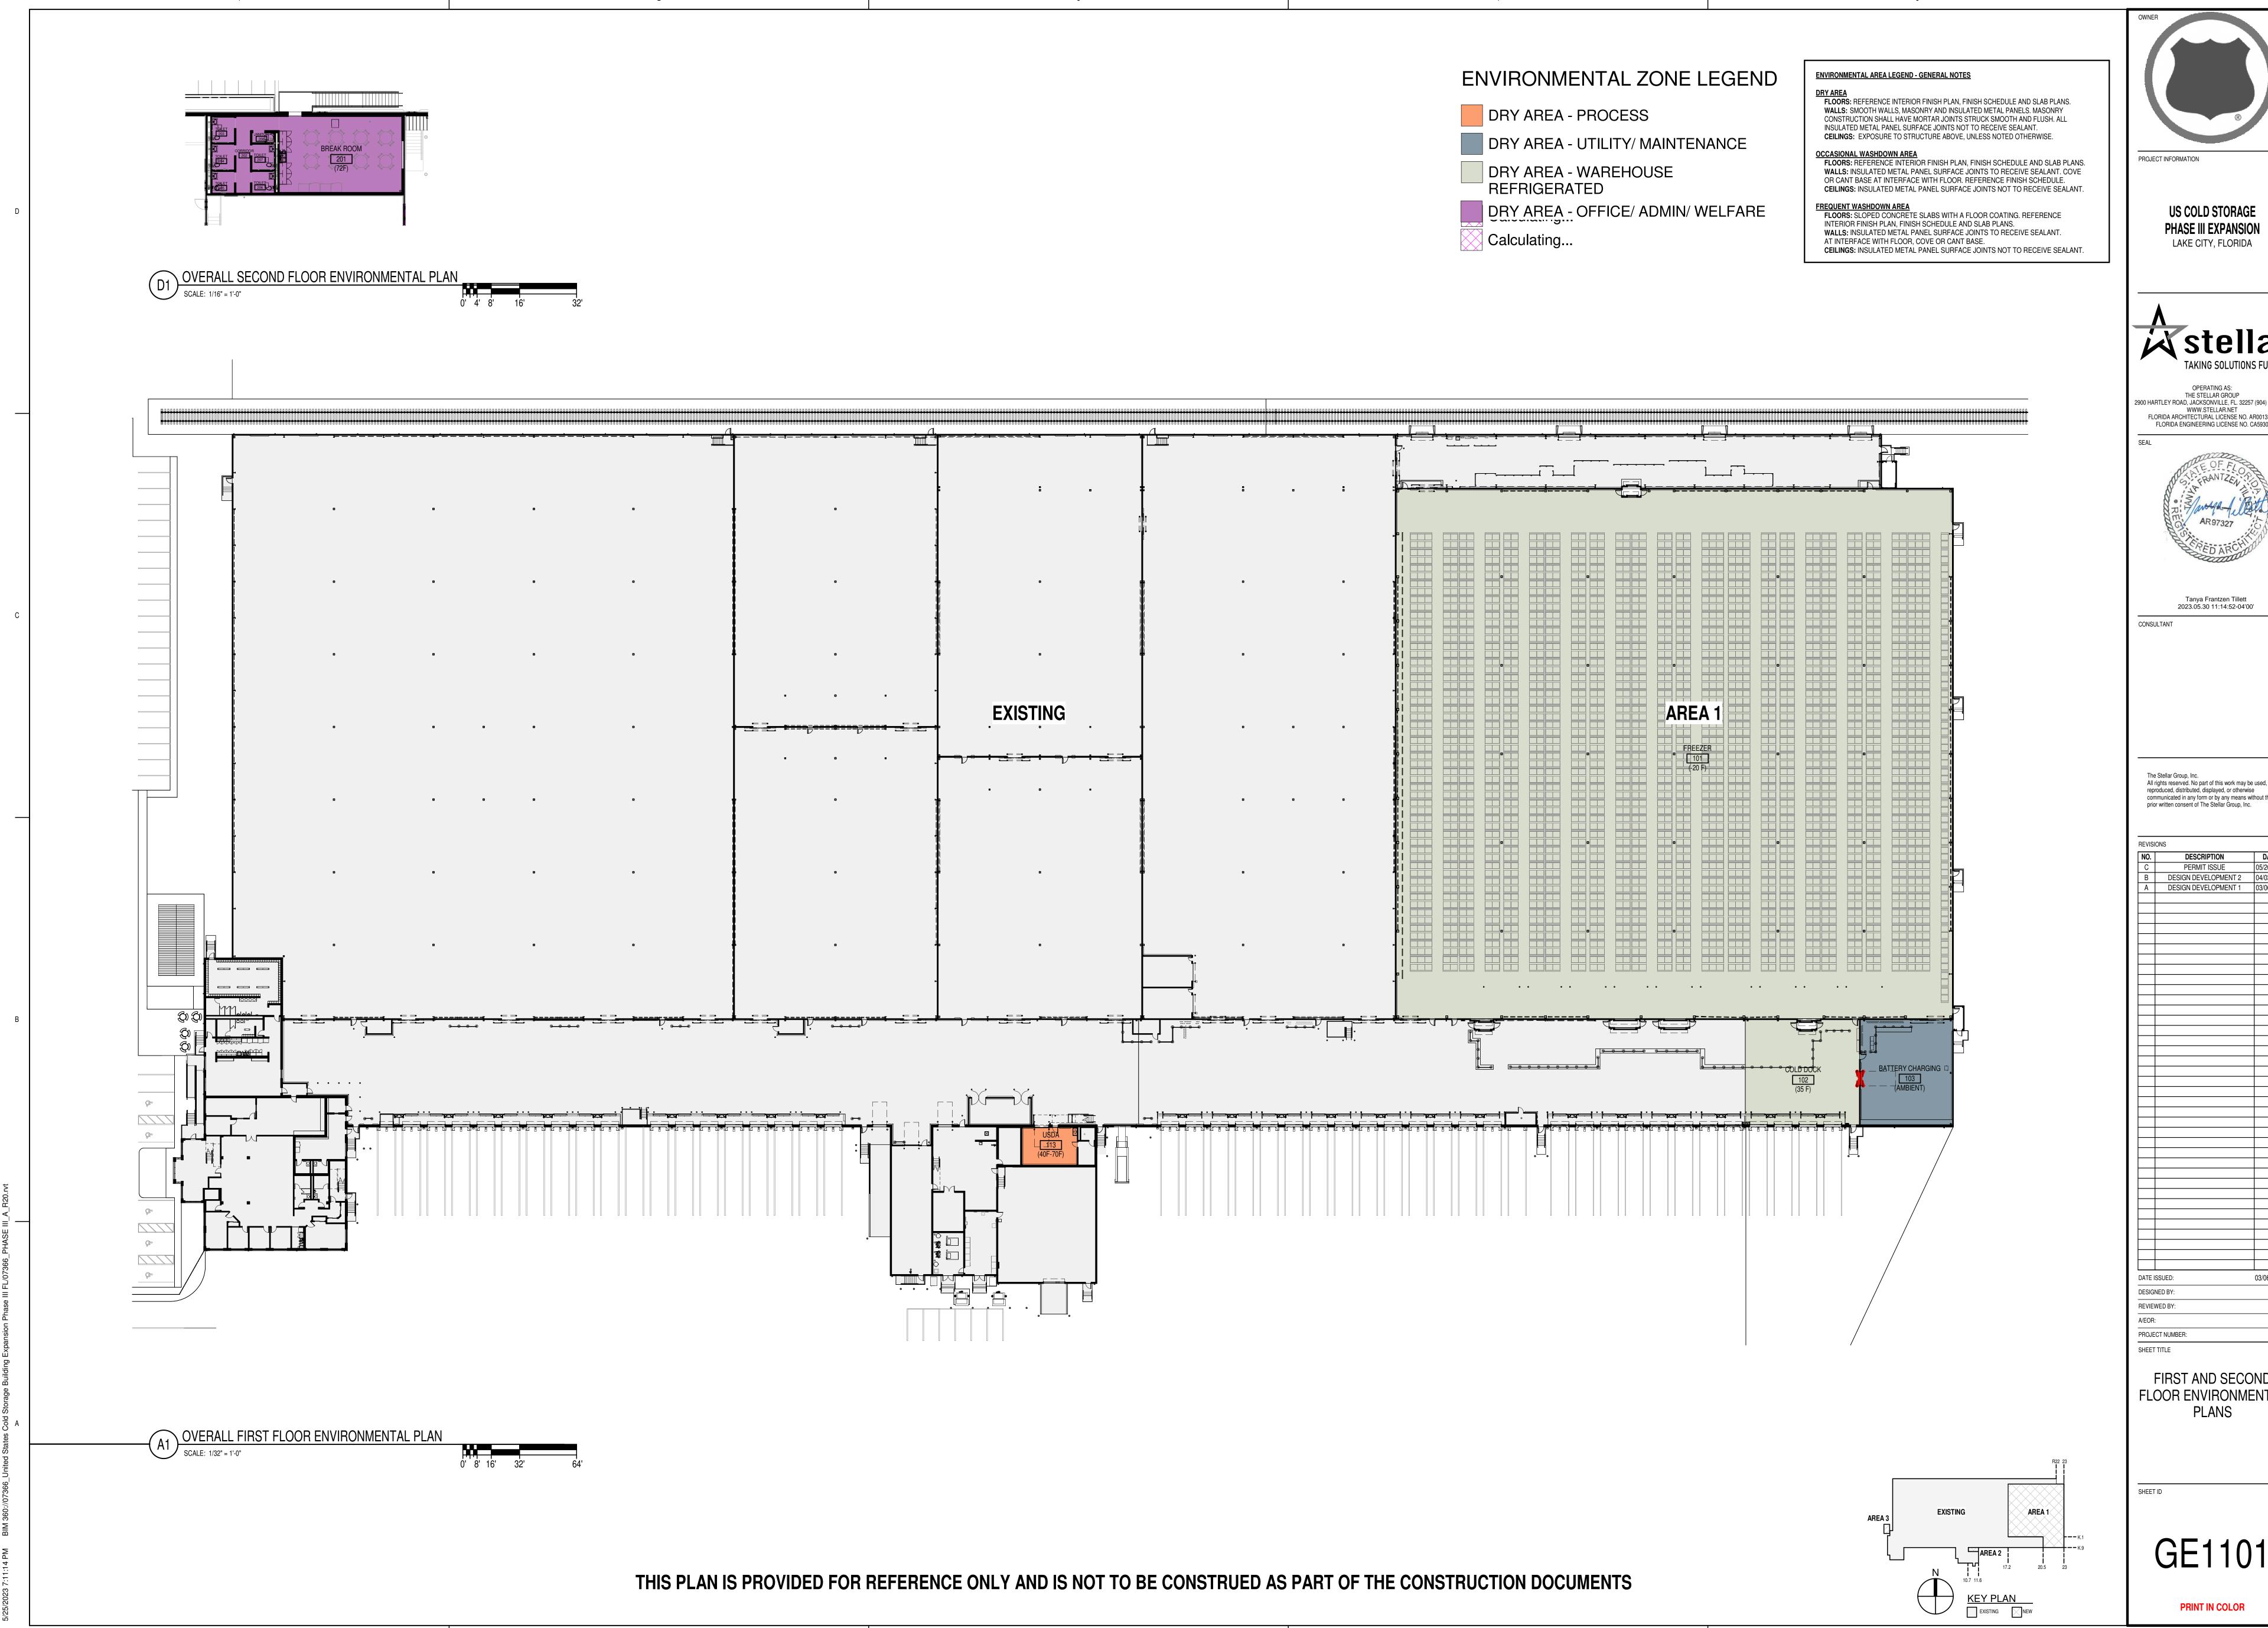

**US COLD STORAGE** PHASE III EXPANSION

OPERATING AS: THE STELLAR GROUP 2900 HARTLEY ROAD, JACKSONVILLE, FL. 32257 (904) 260-2900 WWW.STELLAR.NET FLORIDA ARCHITECTURAL LICENSE NO. AR0013370 FLORIDA ENGINEERING LICENSE NO. CA5930



Tanya Frantzen Tillett 2023.05.30 11:14:52-04'00'

reproduced, distributed, displayed, or otherwise communicated in any form or by any means without the prior written consent of The Stellar Group, Inc.

FIRST AND SECOND FLOOR ENVIRONMENTAL PLANS

GE1101