




FRONT ELEVATION

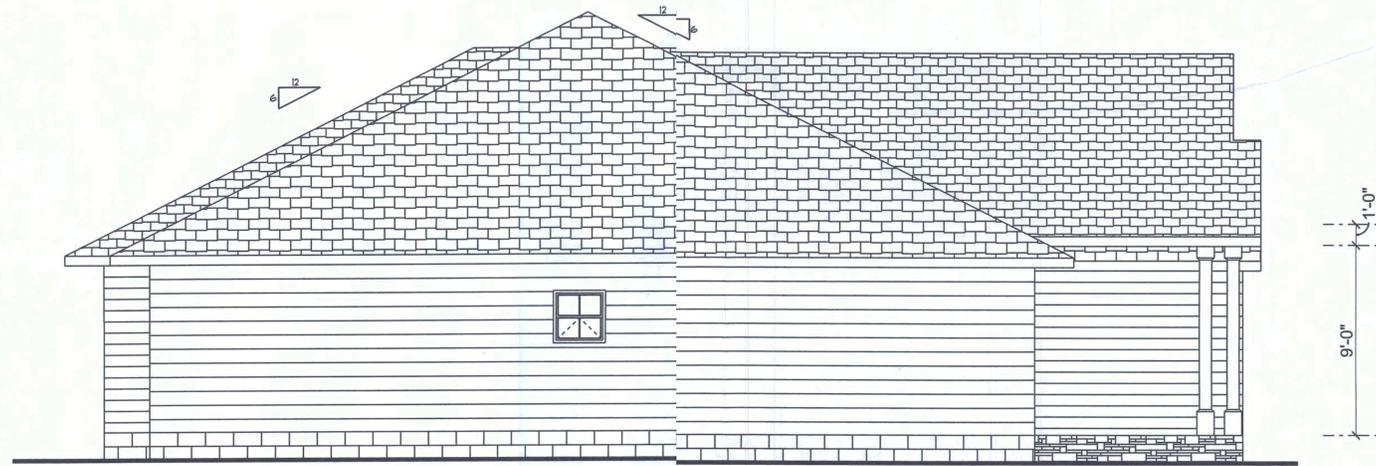

LEFT ELEVATION



DRAWN BY:
 JASON ELIXSON CONSTRUCTION, LLC
 7496 WEST CR. 18
 LAKE BUTLER, FL. 32054
 (386) 623-1741

STEVENS / FOREST COUNTRY


(86) 867-0156

SOFTPLAN
 ARCHITECTURAL DESIGN SOFTWARE


FRONT AND LEFT
 ELEVATION

1/4"=1 FOOT

PAGE
 1

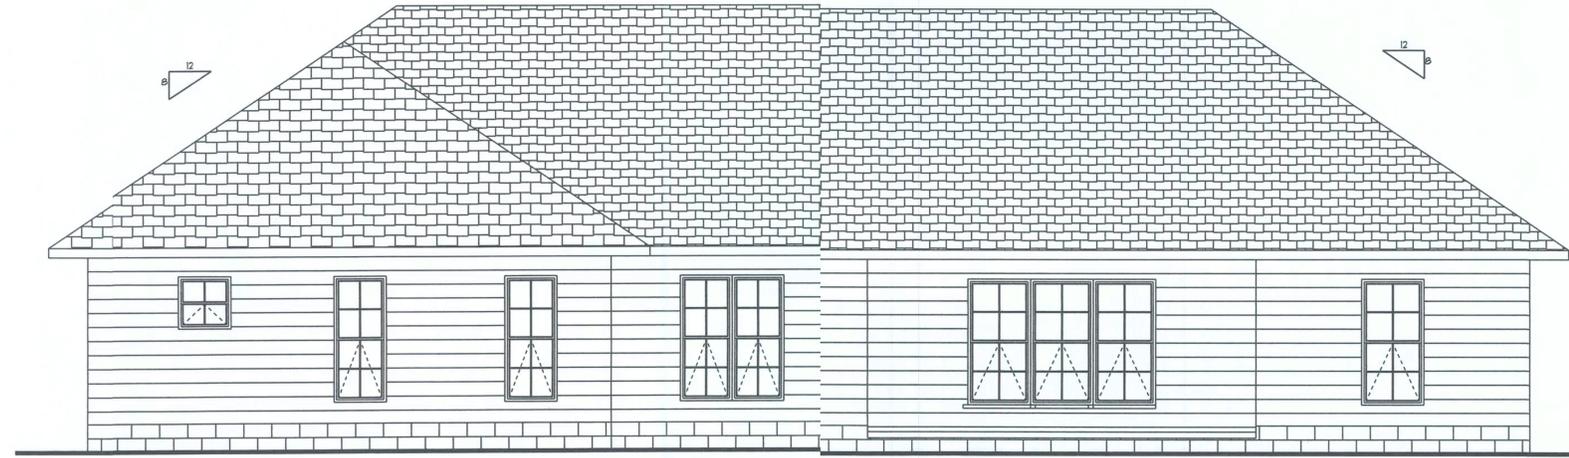

REAR ELEVATION

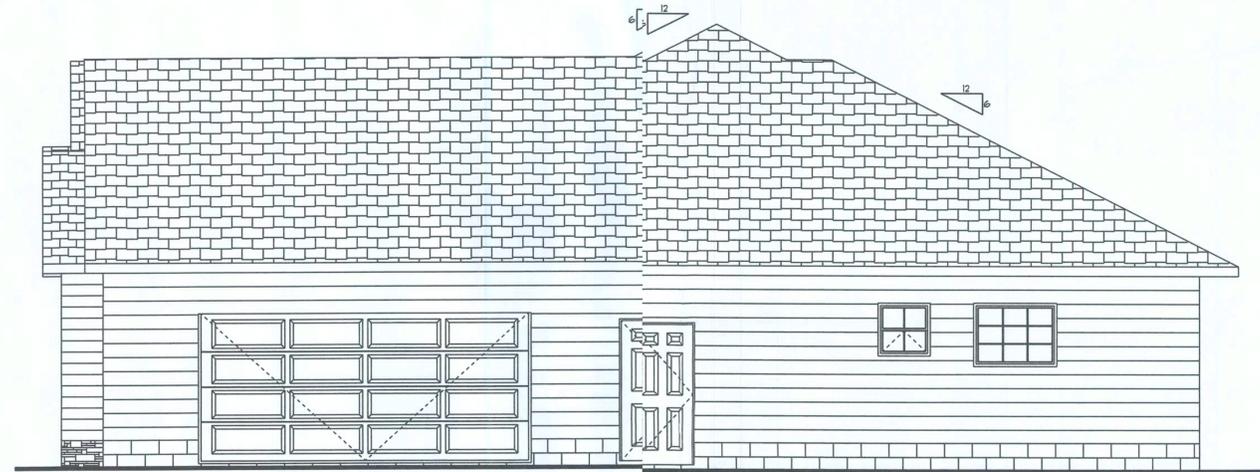

RIGHT ELEVATION

DRAWN BY:
 JASON ELIXSON CONSTRUCTION, LLC
 7490 WEST CR 18
 LAKE BUTLER, FL. 32054
 (386) 623-1741

STEVENS / FOREST COUNTRY


SOFTPLAN
 ARCHITECTURAL DESIGN SOFTWARE

RIGHT AND REAR
 ELEVATION

1/4"=1 FOOT

PAGE
 2

It is important that the Client and Contractor examine the drawings and documentation in detail. It shall be the final responsibility of the Contractor to review and double check the plans for accuracy and compliance with regulatory agencies. It is customary and ordinary not to include details well within the knowledge of licensed Contractor. If necessary, further clarification of these plans should be achieved before signing the construction contract and obtaining a building permit, otherwise the Contractor assumes responsibility for the construction in question. Methods of construction shall be determined by the Contractor.

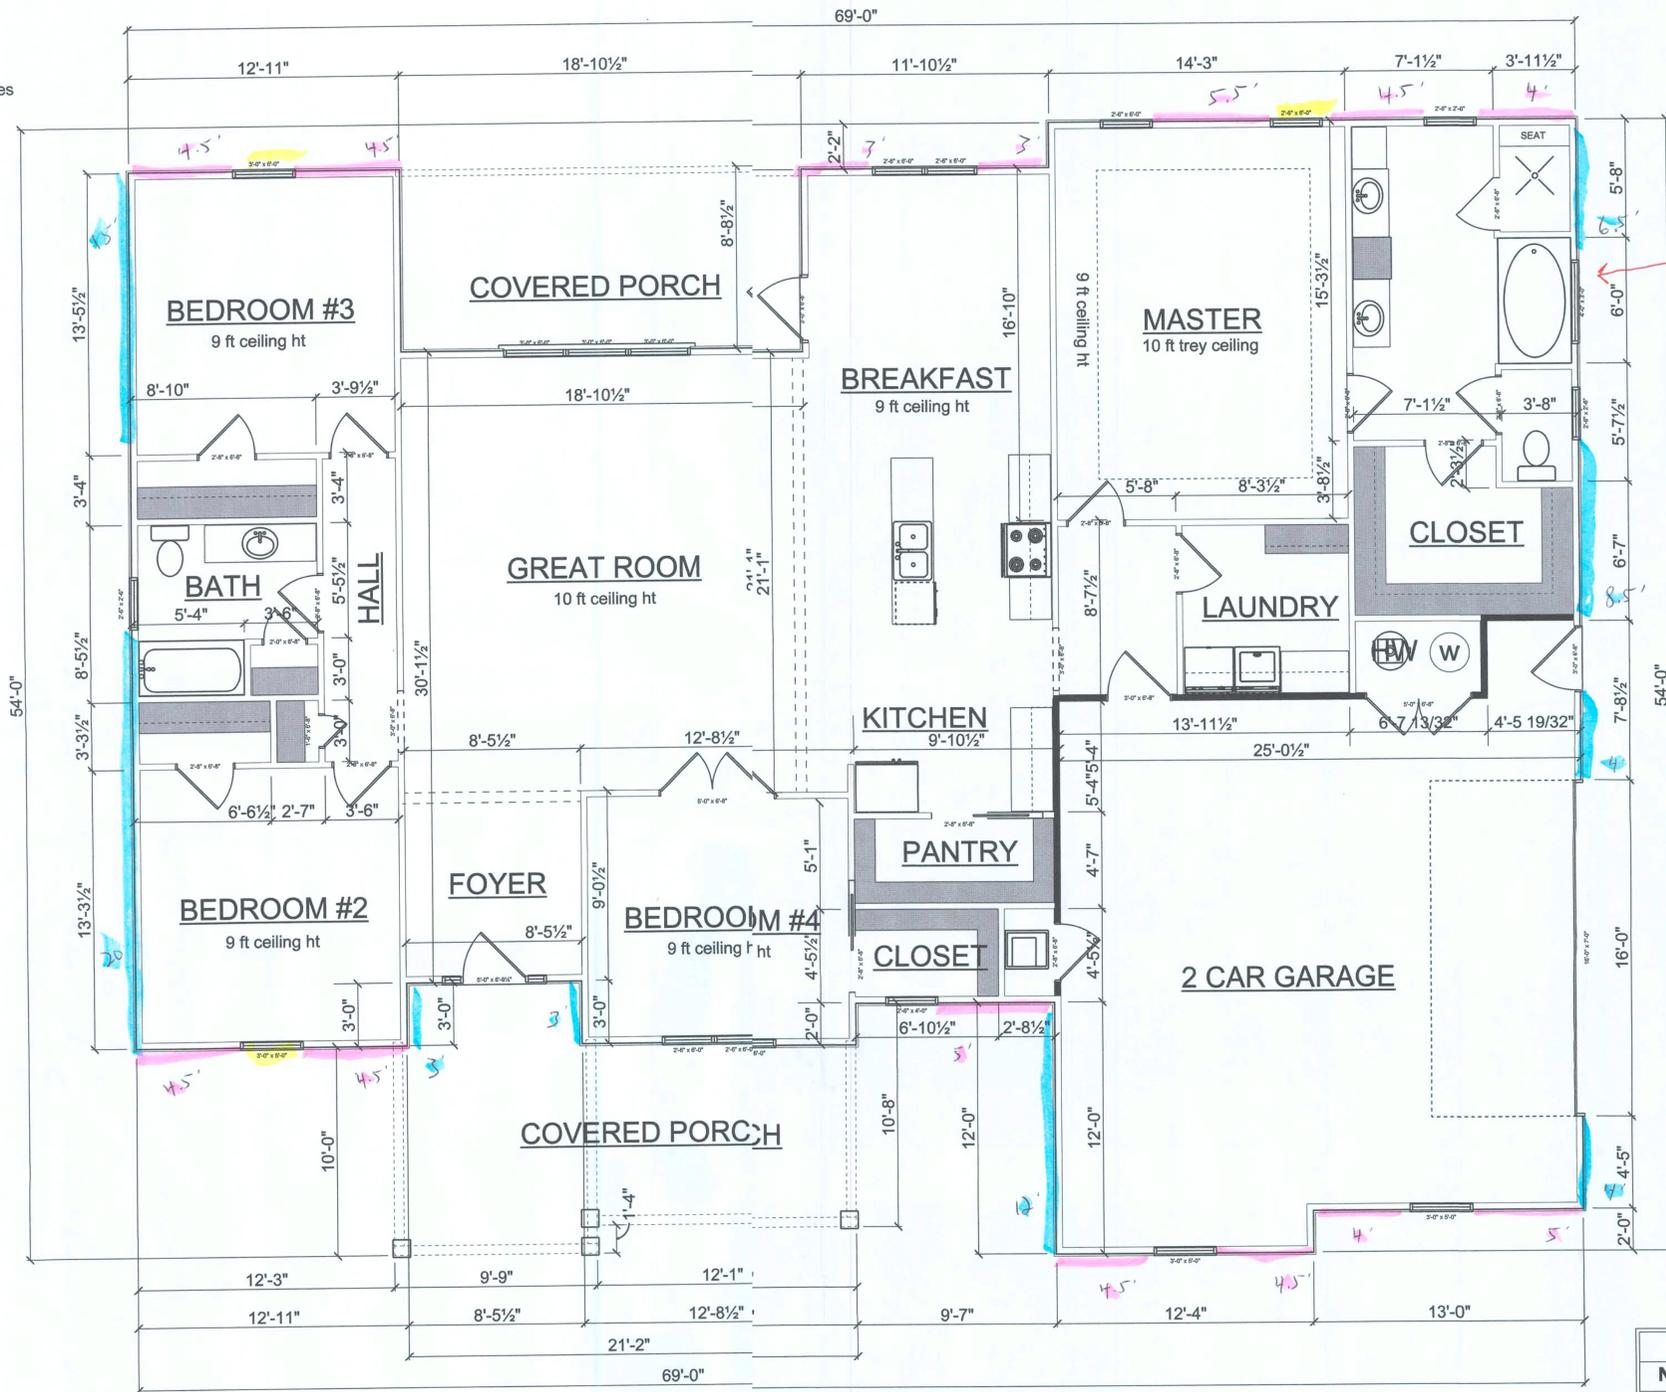

AREA SCHEDULE	
NAME	AREA
HEATED	2277 sq. ft.
GARAGE	688 sq. ft.
PORCHES	391 sq. ft.
TOTAL	3356 sq. ft.

7.25 = 7.6
long = 6.1

FLOOR PLAN

DRAWN BY:
JASON ELIXSON CONSTRUCTION, LLC
 7490 WEST CR. 18
 LAKE BUTLER, FL. 32054
 (386) 623-1741

STEVENS / FOREST COUNTRY

SOFTPLAN
 ARCHITECTURAL DESIGN SOFTWARE

FLOOR PLAN
 1/4"=1 FOOT

PAGE
 3

ELECTRICAL LEGEND	
ELECTRICAL	SYMBOL
ceiling fan globe 01	
can light 6inch	
fluorescent light 2 x 4	
spotlight double	
electrical meter	
electrical panel	
fan	
light	
outlet	
outlet 220v	
outlet gfi	
outlet wp	
smoke detector	
switch	
switch 3 way	
switch double	
switch triple	

ELECTRICAL PLAN NOTES

WIRE ALL APPLIANCES, HVAC UNIT ANIOTHER EQUIPMENT PER MANUFACTURER SPE S


INSTALLATION SHALL BE PER NATIONA ELECTRIC CODE

TELEPHONE, T.V. AND OTHER LOW VOL'AGE DEVICES OR OUTLETS SHALL BE AS PE THE OWNERS DIRECTIONS AND IN ACCORDANCE WITH APPLICABLE SECTIONS OF NEC-LATEST EDITIONS

ALL SMOKE DETECTORS SHALL BE 120' WITH BATTERY BACKUP OF THE PHOTOELECTRIC TYPI AND SHALL BE INTERLOCKED TOGETHER

ALL MATERIAL SHALL HAVE A UL LABELDR LISTING

ALL OUTLETS TO BE ARC-FAULT BREAKRS OR GFI OUTLETS

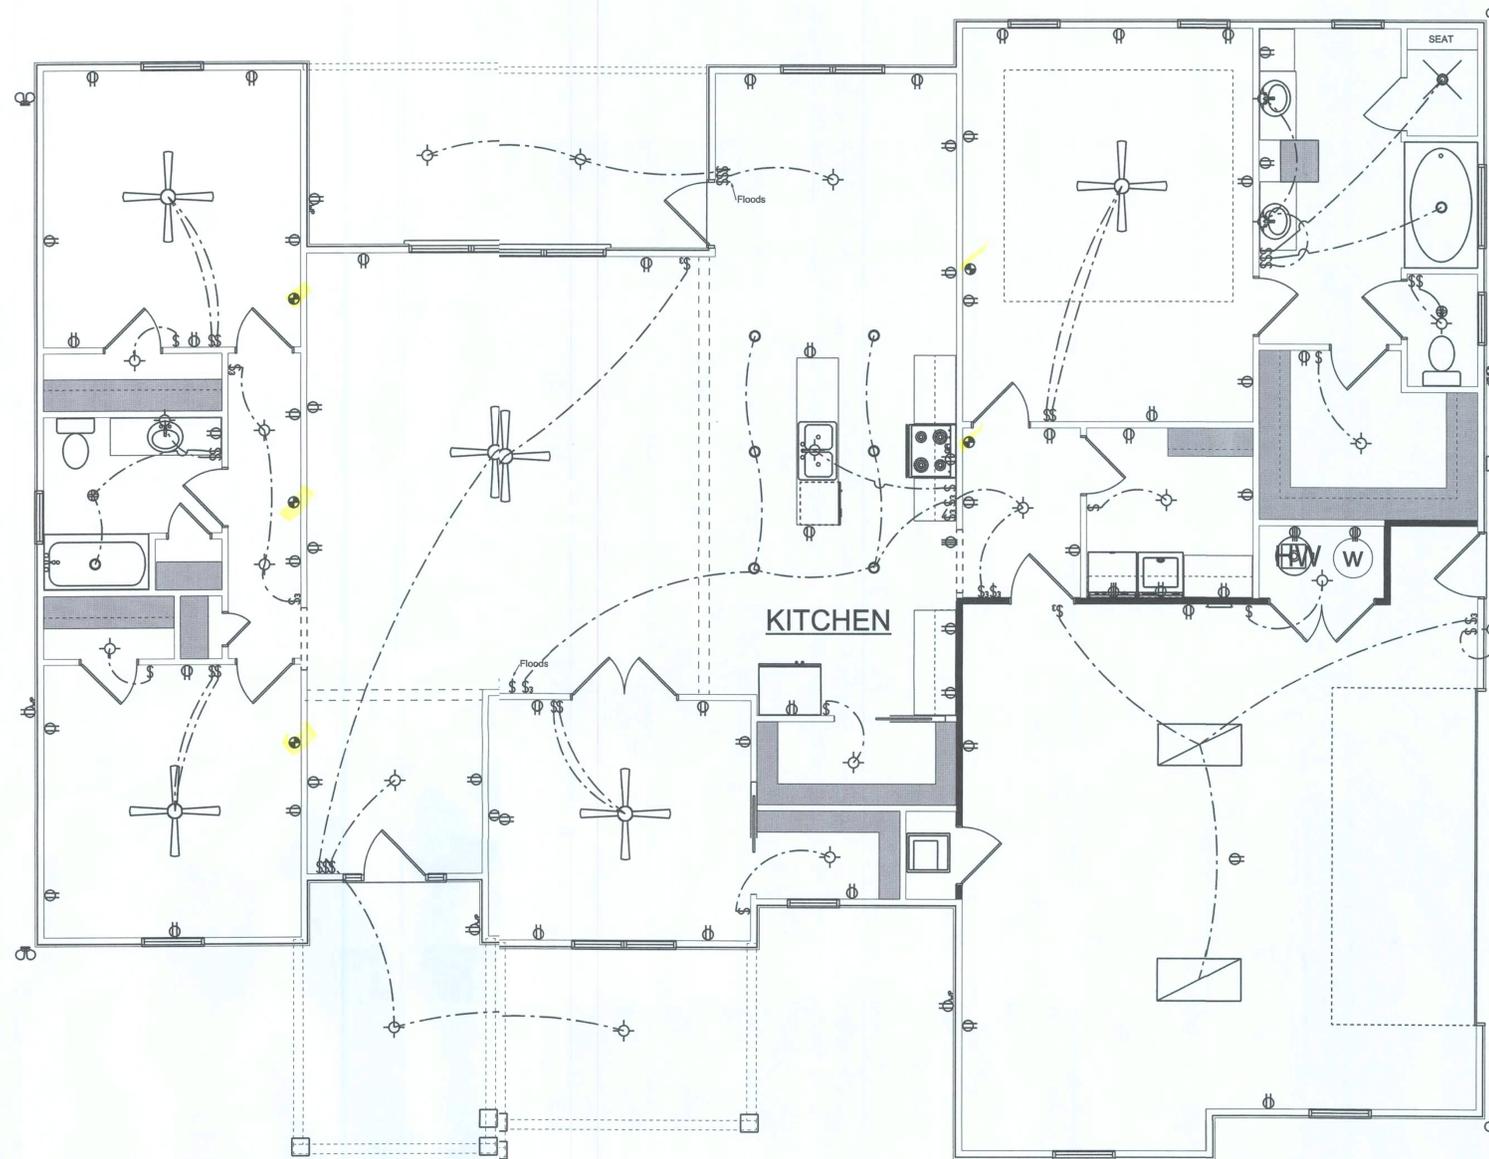

ELECTRICAL PLAN

DRAWN BY:
 JASON ELIXSON CONSTRUCTION, LLC
 7490 WEST CR. 18
 LAKE BUTLER, FL. 32054
 (386) 623-1741



STEVENS / FOREST COUNTRY

SOFTPLAN
 ARCHITECTURAL DESIGN SOFTWARE

ELECTRICAL PLAN

1/4"=1 FOOT


PAGE
 4

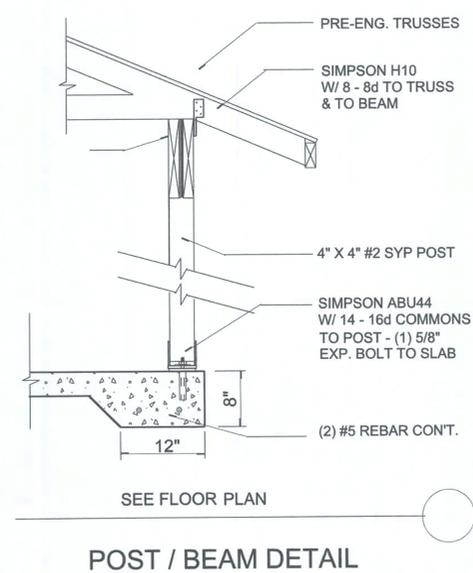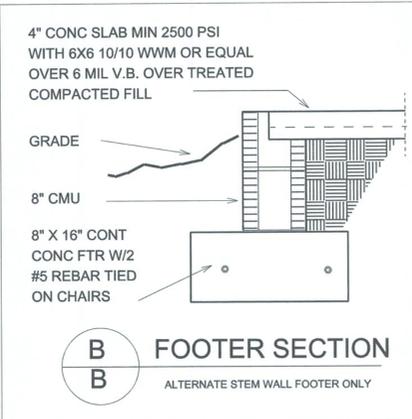



- FOUNDATION NOTES**
1. Footing trenches and the area within the foundation wall shall be free of all deleterious material.
 2. All reinforcing rods shall be Grade 40 (40,000 p.s.i.) #5 deformed bars with a 25" min. lap and placed on support chairs @ 6" o.c.
 3. All concrete for slabs, pads, and walkways shall be 2500 p.s.i. minimum at 28 days. Concrete for downpours and bond beams shall be 3000 p.s.i. (peg gravel mix).
 4. Provide 6 mil vapor barrier under all concrete slabs with joints lapped 6" and taped.
 5. Slab reinforcing shall be 6 X 6 #10/10 welded wire fabric (steel), edge lap 6" and tied.
 6. All fill dirt shall be clean sand, free of deleterious material and laid in 1 1/2" lifts. Each lift to be wetted and compacted prior to next lift.
 7. All fill dirt within the foundation walls shall be termite treated and according to the standards of the National Pest Control Association with a minimum one year warranty.
 8. Slope all exterior slabs and garage floor slab for proper drainage.

TYPICAL FOUNDATION WALL
 8" CONCRETE BLOCK STEM WALL ON 20"X10" POURED CONCRETE FOOTING REINFORCED WITH SHOP BENT ELBOWS ON CORNERS TO PROVIDE MIN. 25" LAP

TYPICAL FLOOR SLAB
 4" CONCRETE FLOOR SLAB REINFORCED WITH 6X6-10/10 WELDED WIRE MESH PLACED OVER 6-MIL POLYETHYLENE VAPOR BARRIER OVER COMPACTED AND TERMITE-TREATED CLEAN FILL

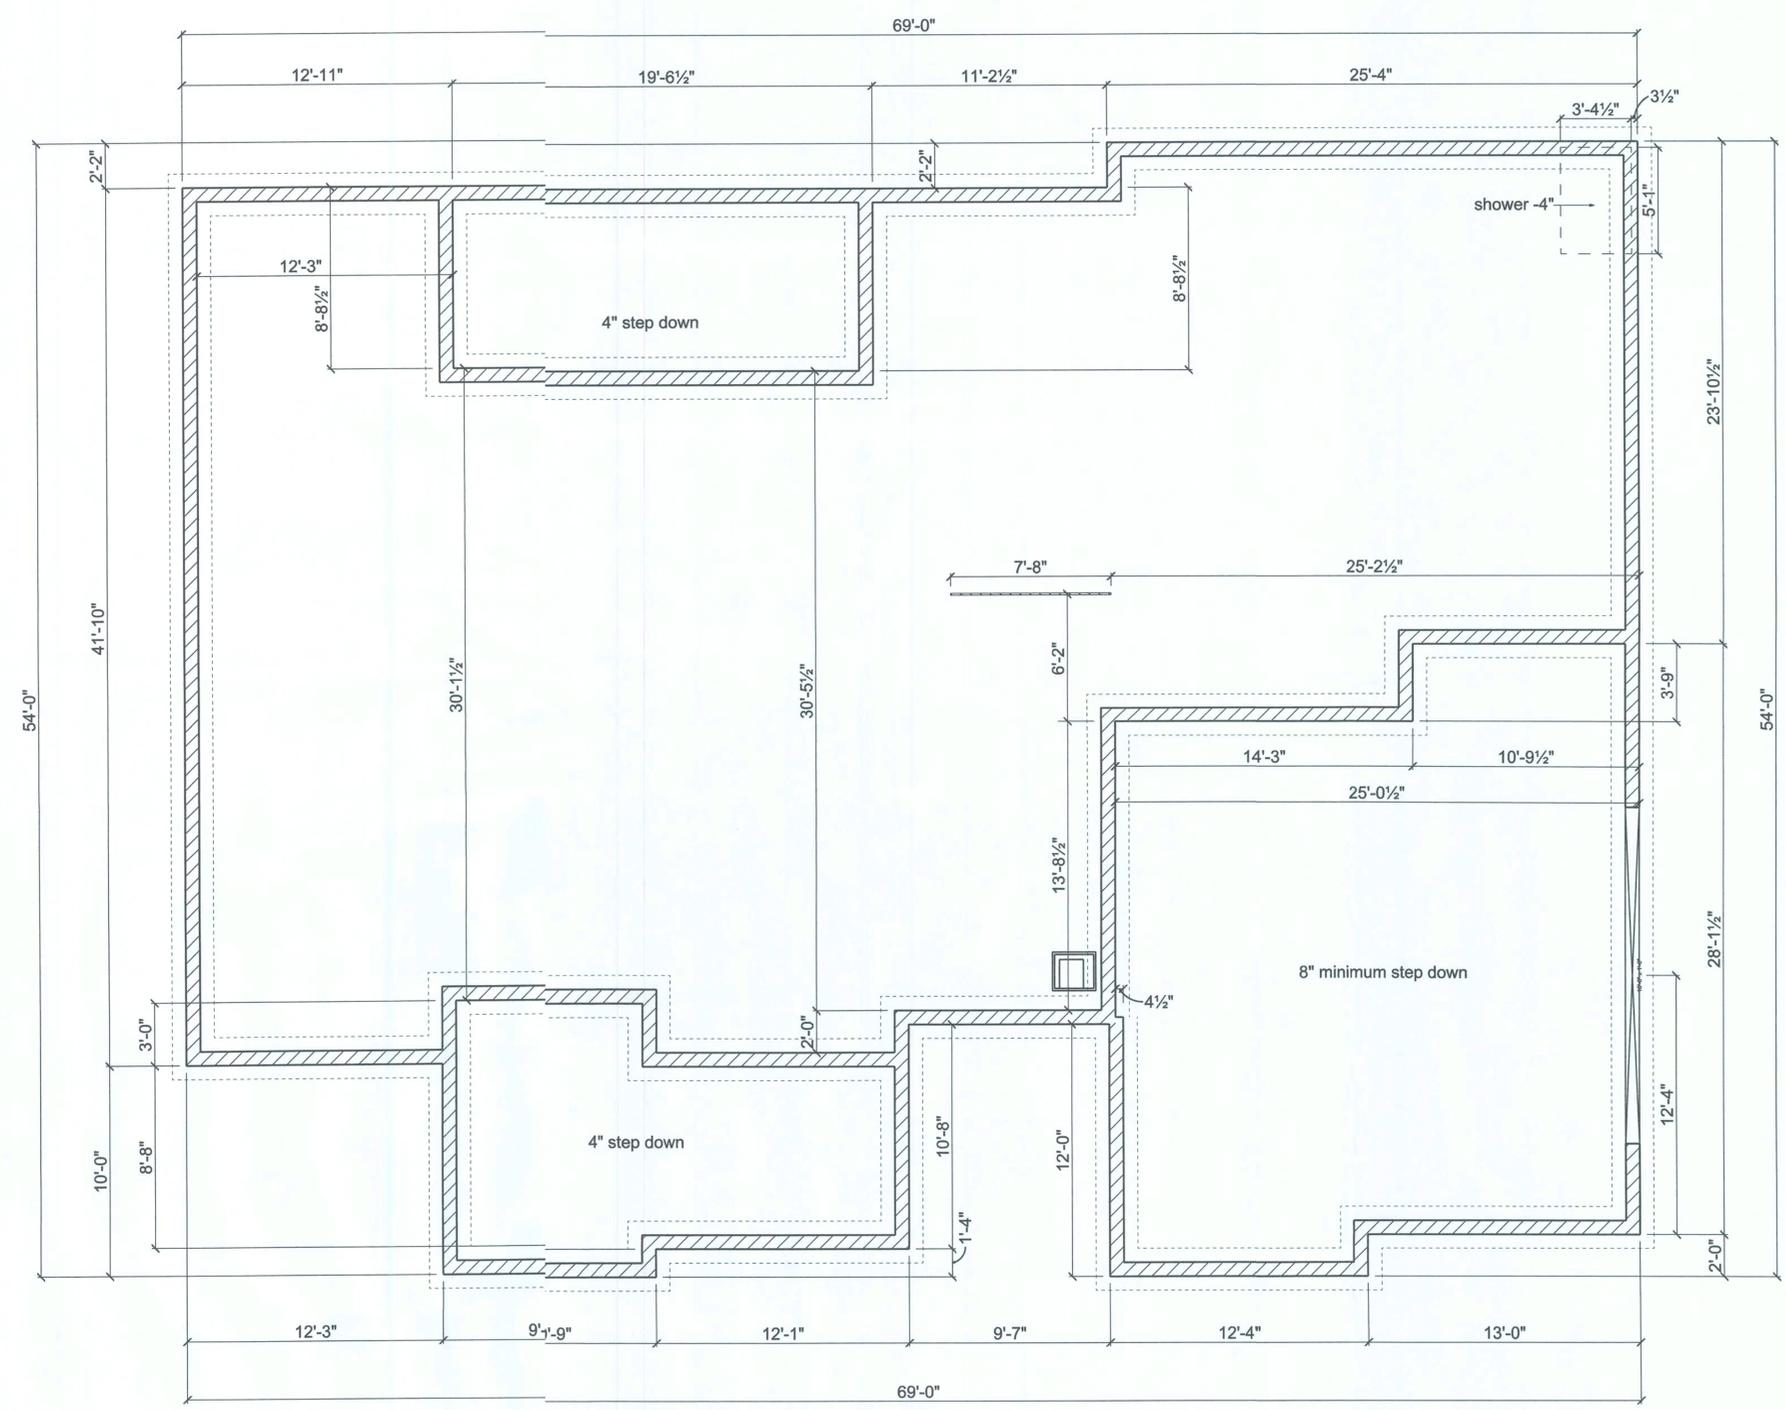

FOUNDATION PLAN

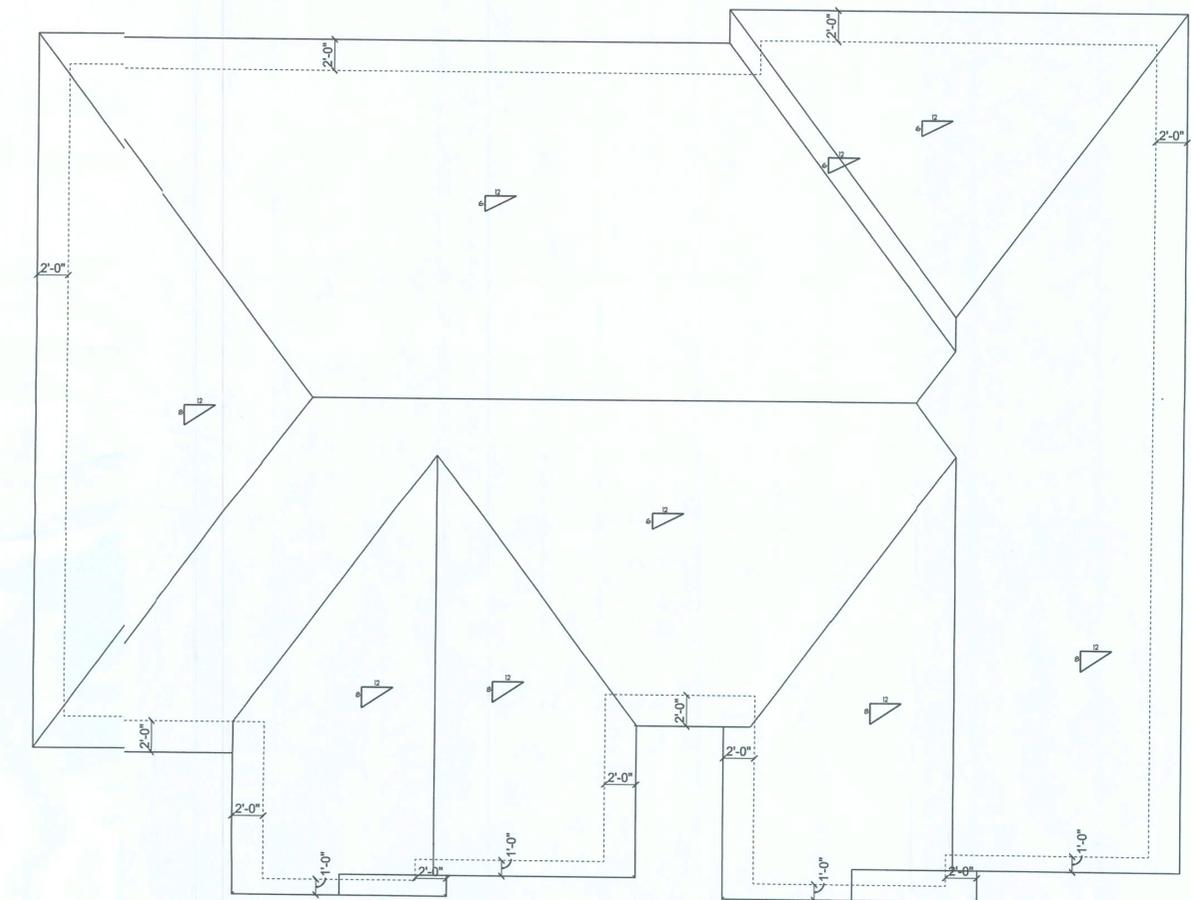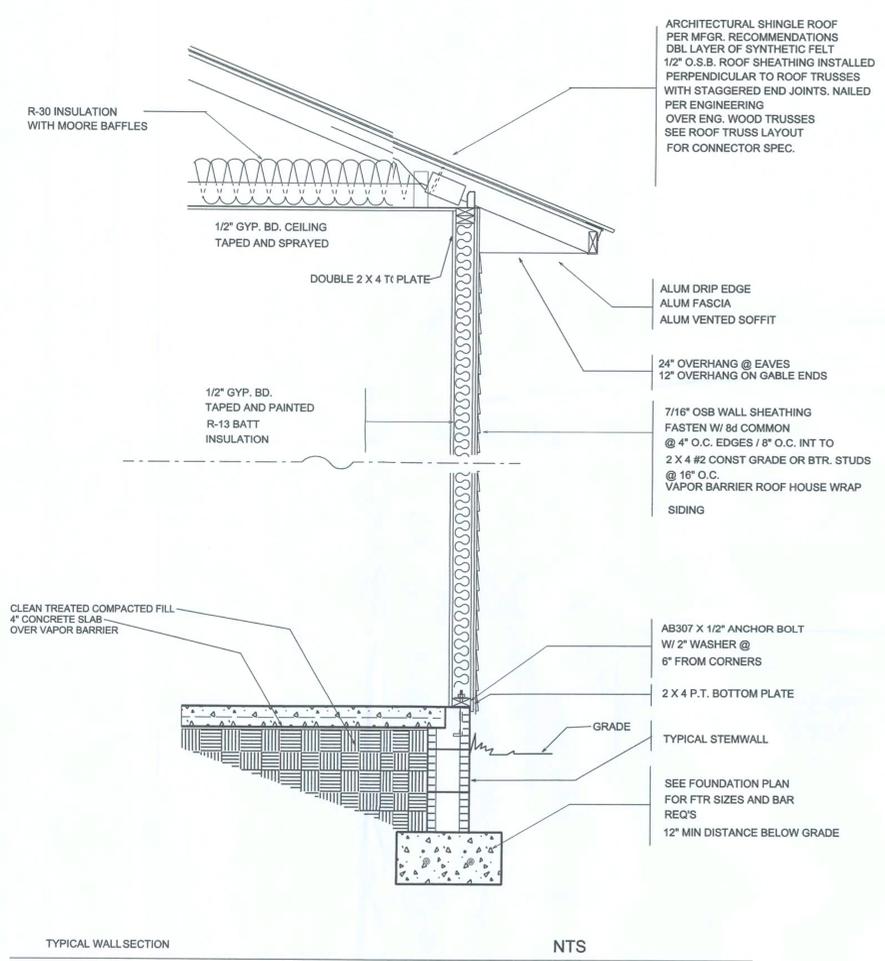

DRAWN BY:
JASON ELIXSON CONSTRUCTION, LLC
 7490 WEST CR. 18
 LAKE BUILER, FL. 37054
 (386) 623-1741

SOFTPLAN
 ARCHITECTURAL DESIGN SOFTWARE

STEVENS / FOREST COUNTRY

ROOF PLAN
WALL SECTION

PAGE
6