


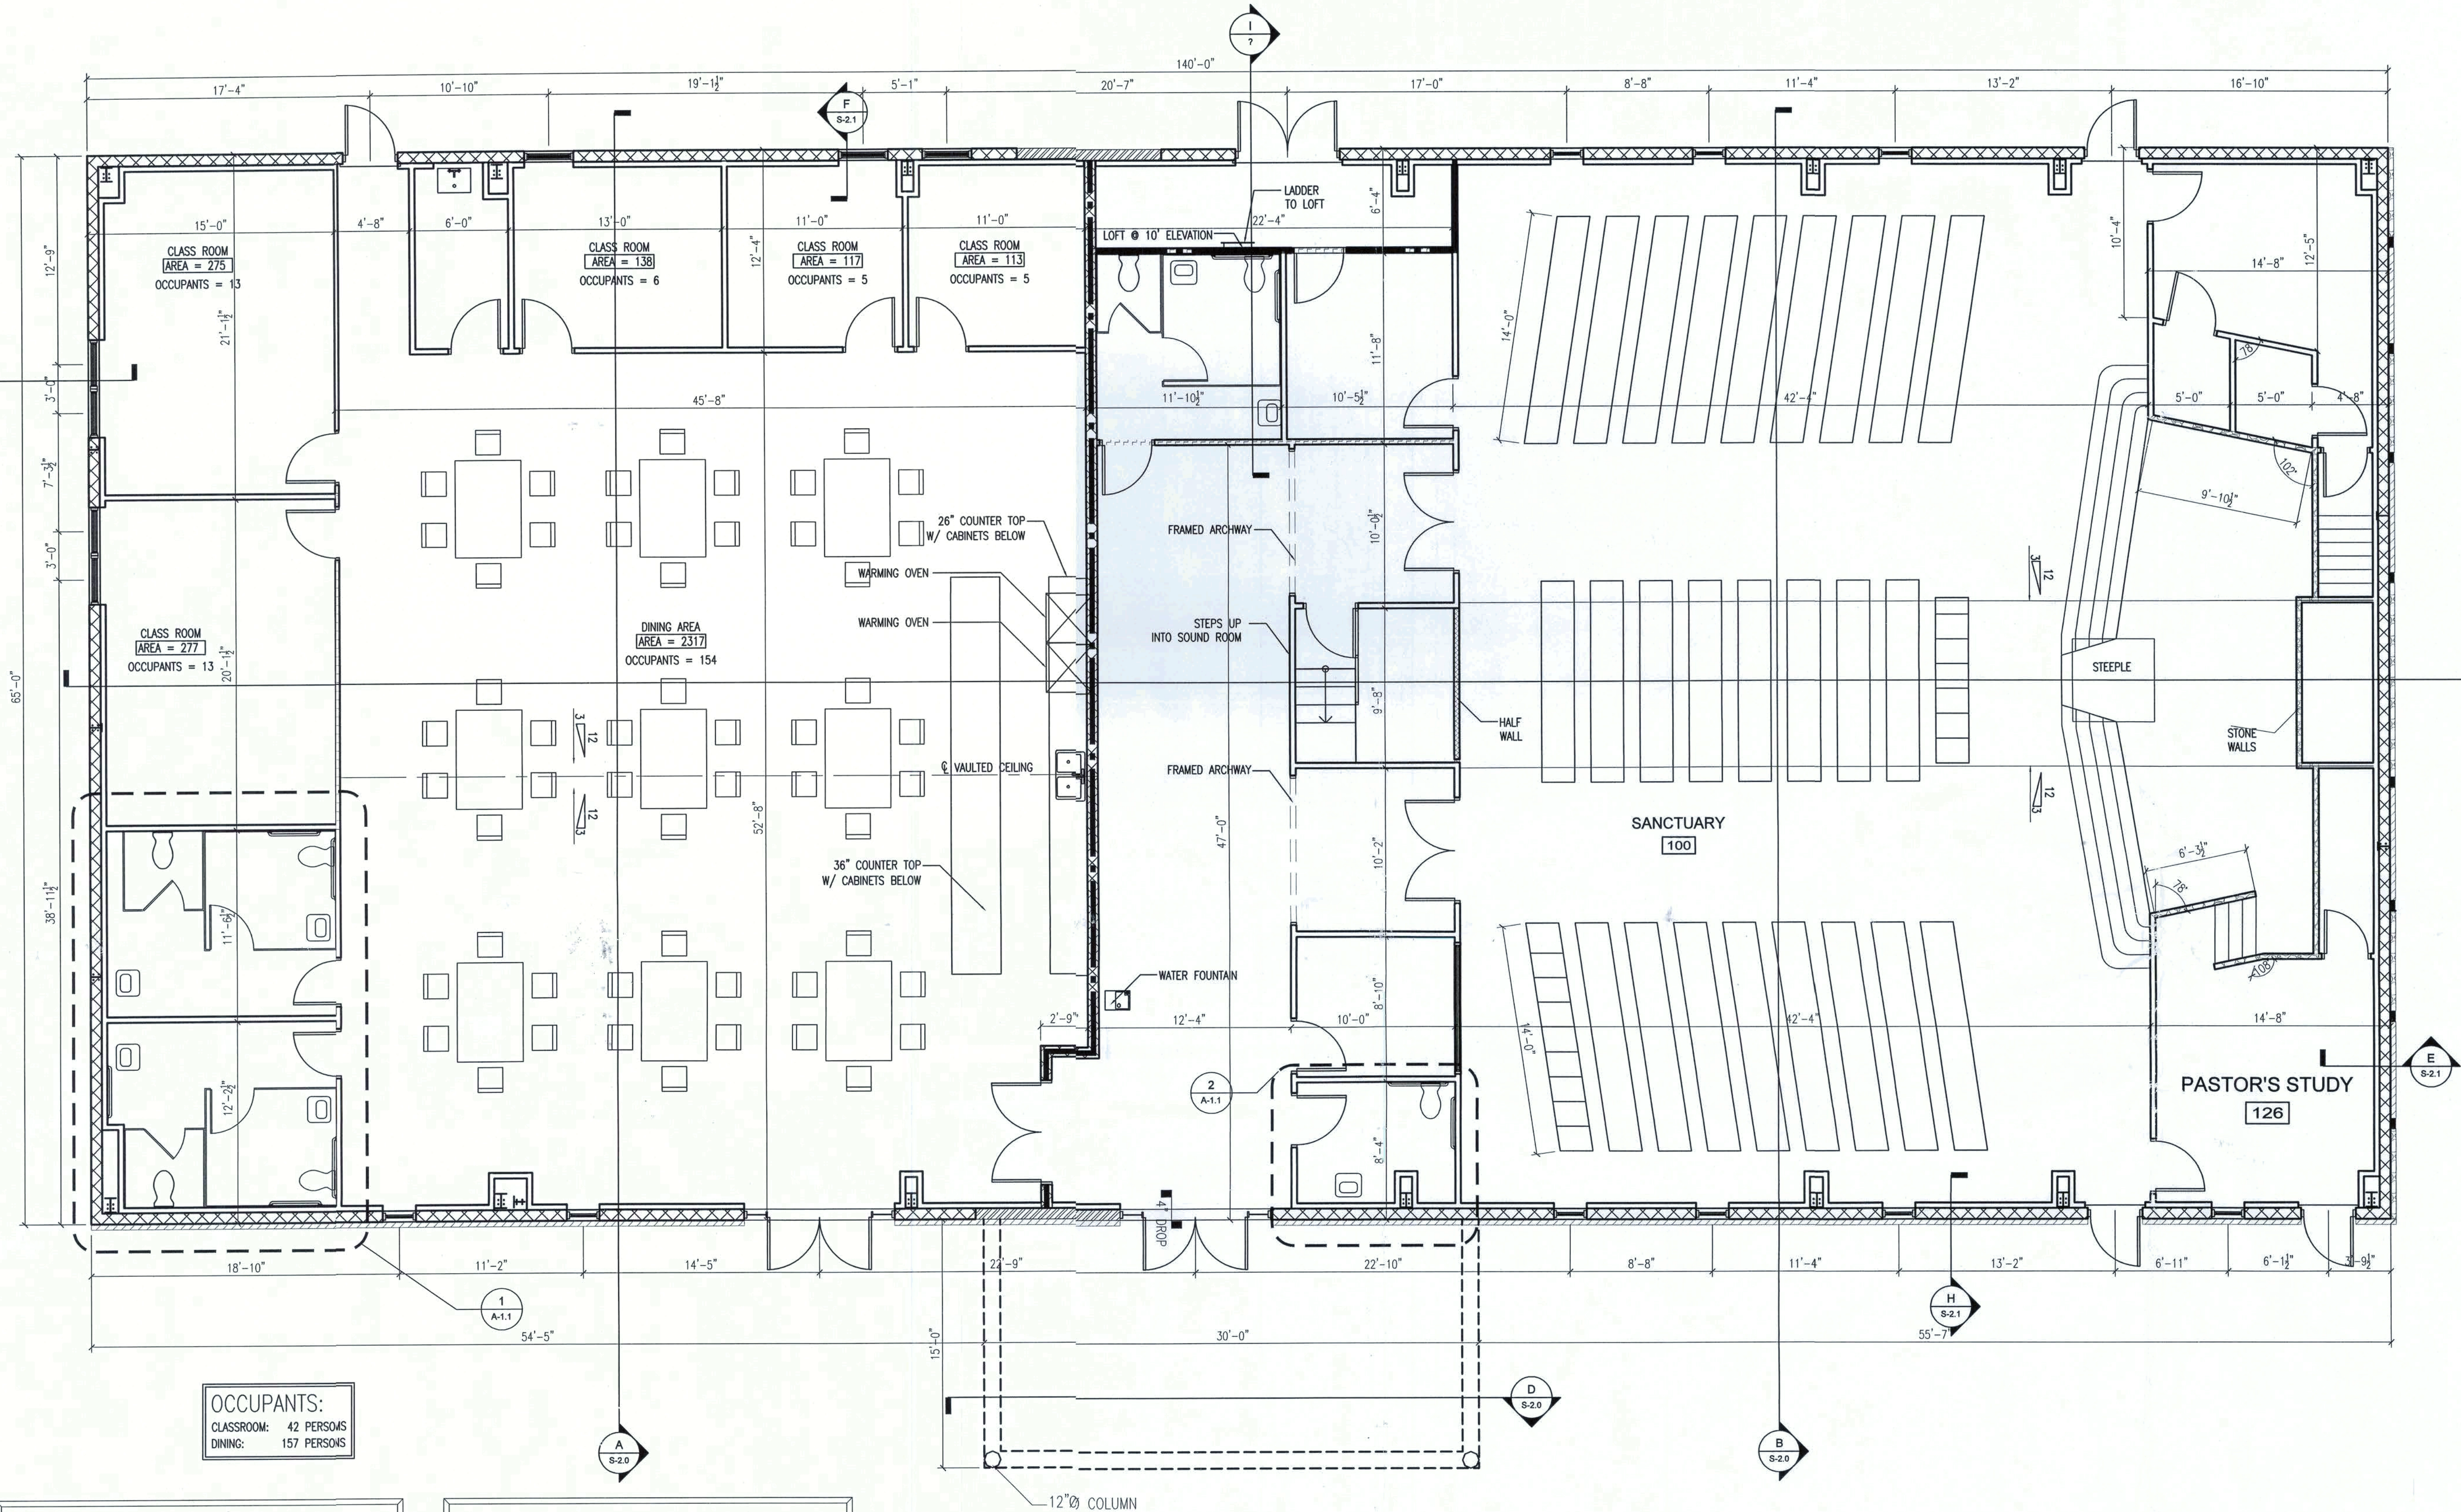

OCCUPANTS:
CLASSROOM: 42 PERSONS
DINING: 157 PERSONS

WALL LEGEND	
	= INTERIOR WALLS
	3 5/8" METAL STUDS
	= INTERIOR HALF WALLS
	42" A.F.F. 3 5/8" METAL STUDS
	= 1 HOUR FIRE WALL
	= INTERIOR BEARING WALL
	= DECORATIVE STONE WALL
	= DECORATIVE BRICK WALL
	= 8" METAL WALL

BUILDING AREA	
BUILDING AREA	= 9100 S.F.
COMMON AREA & CLASS ROOMS	= 4377 S.F.
SANCTUARY & ENTRANCE AREA	= 4416 S.F.
FRONT PORCH	= 450 S.F.

FLOOR PLAN
SCALE: 3/16" = 1'-0"

ISSUED FOR APPROVAL


[Signature]
7/27/07

REVISION NOTES	
REV #	DATE
1	10-20-06
ISSUED FOR CONSTRUCTION	
PROJECT NUMBER PF06-193S	
DRAWN BY D. PRICE	
CHECKED BY G.G.	
A-1.0	
SHEET 1 OF 16	

P.O. Box 187
130 West Howard Street
Live Oak FL 32064
Phone: (386) 362-3678
Fax: (386) 362-6133
Gary Gill, PE 51942
Auth. # 9461

STRUCTURAL/CIVIL ENGINEERS

7th ADVENTIST CHURCH
NEW WORSHIP CENTER
COLUMBIA COUNTY, FLORIDA

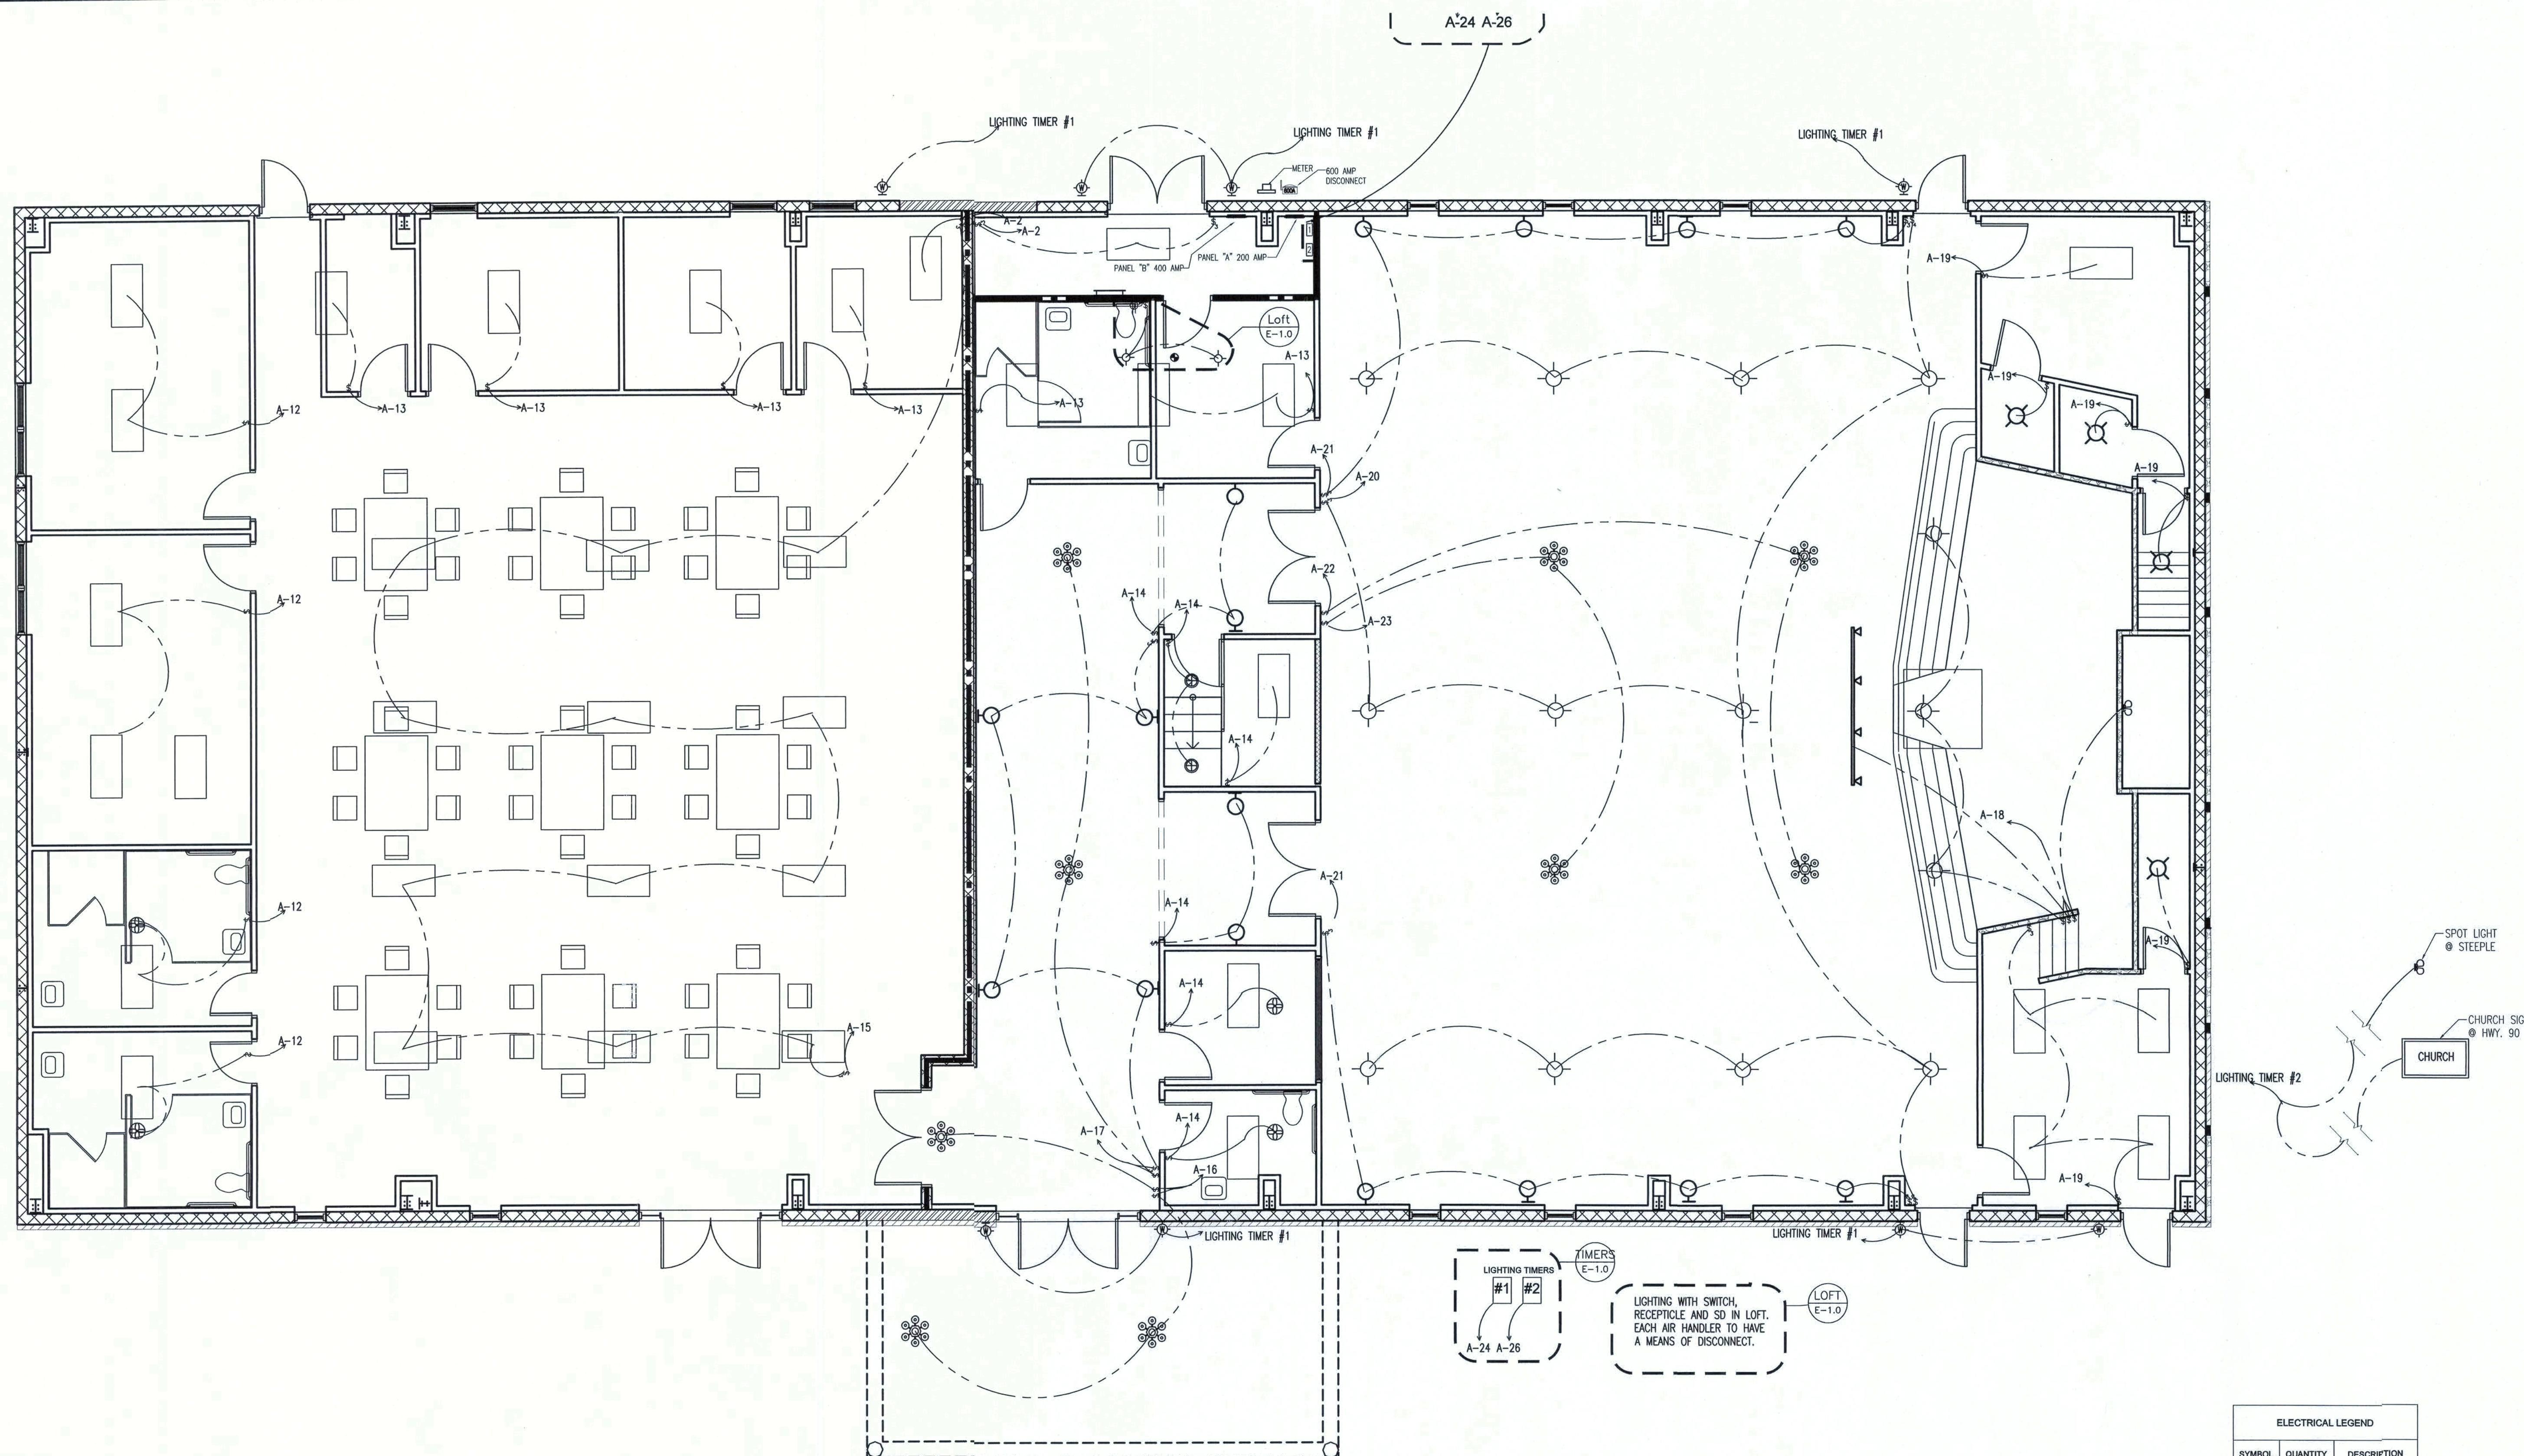


LIGHTING PLAN
SCALE: 3/16" = 1'-0"

ELECTRICAL LEGEND		
SYMBOL	QUANTITY	DESCRIPTION
	11	SPOT LIGHT
	3	DIRECTIONAL SPOT LIGHT
	9	DECORATIVE HANGING CHANDELER
	47	24" x 28" FLUORESCENT LIGHT
	3	EXHAUST FAN
	8	COACH LIGHT
	29	SINGLE POLE SWITCH
	14	3 WAY SWITCH
	1	4 WAY SWITCH
	1	METER
	2	PANEL W/ MAIN BREAKER
	2	RECESSED CAN LIGHT
	2	SURFACE MOUNT GLOBE LIGHT

ISSUED FOR APPROVAL

Lee
9/27/07

REVISION NOTES	ISSUED FOR CONSTRUCTION
REV #	DATE
-	10-20-06
P.O. Box 187 130 West Howard Street Live Oak FL 32064 Phone: (386) 362-3678 Fax: (386) 362-6133 GARY GILL, PE 51942 Auth. # 9461	
7th ADVENTIST CHURCH NEW WORSHIP CENTER COLUMBIA COUNTY, FLORIDA	
LIGHTING PLAN	
PROJECT NUMBER PF06-193S	
DRAWN BY D. PRICE	
CHECKED BY G.G.	
E-1.0	
SHEET 12 OF 16	

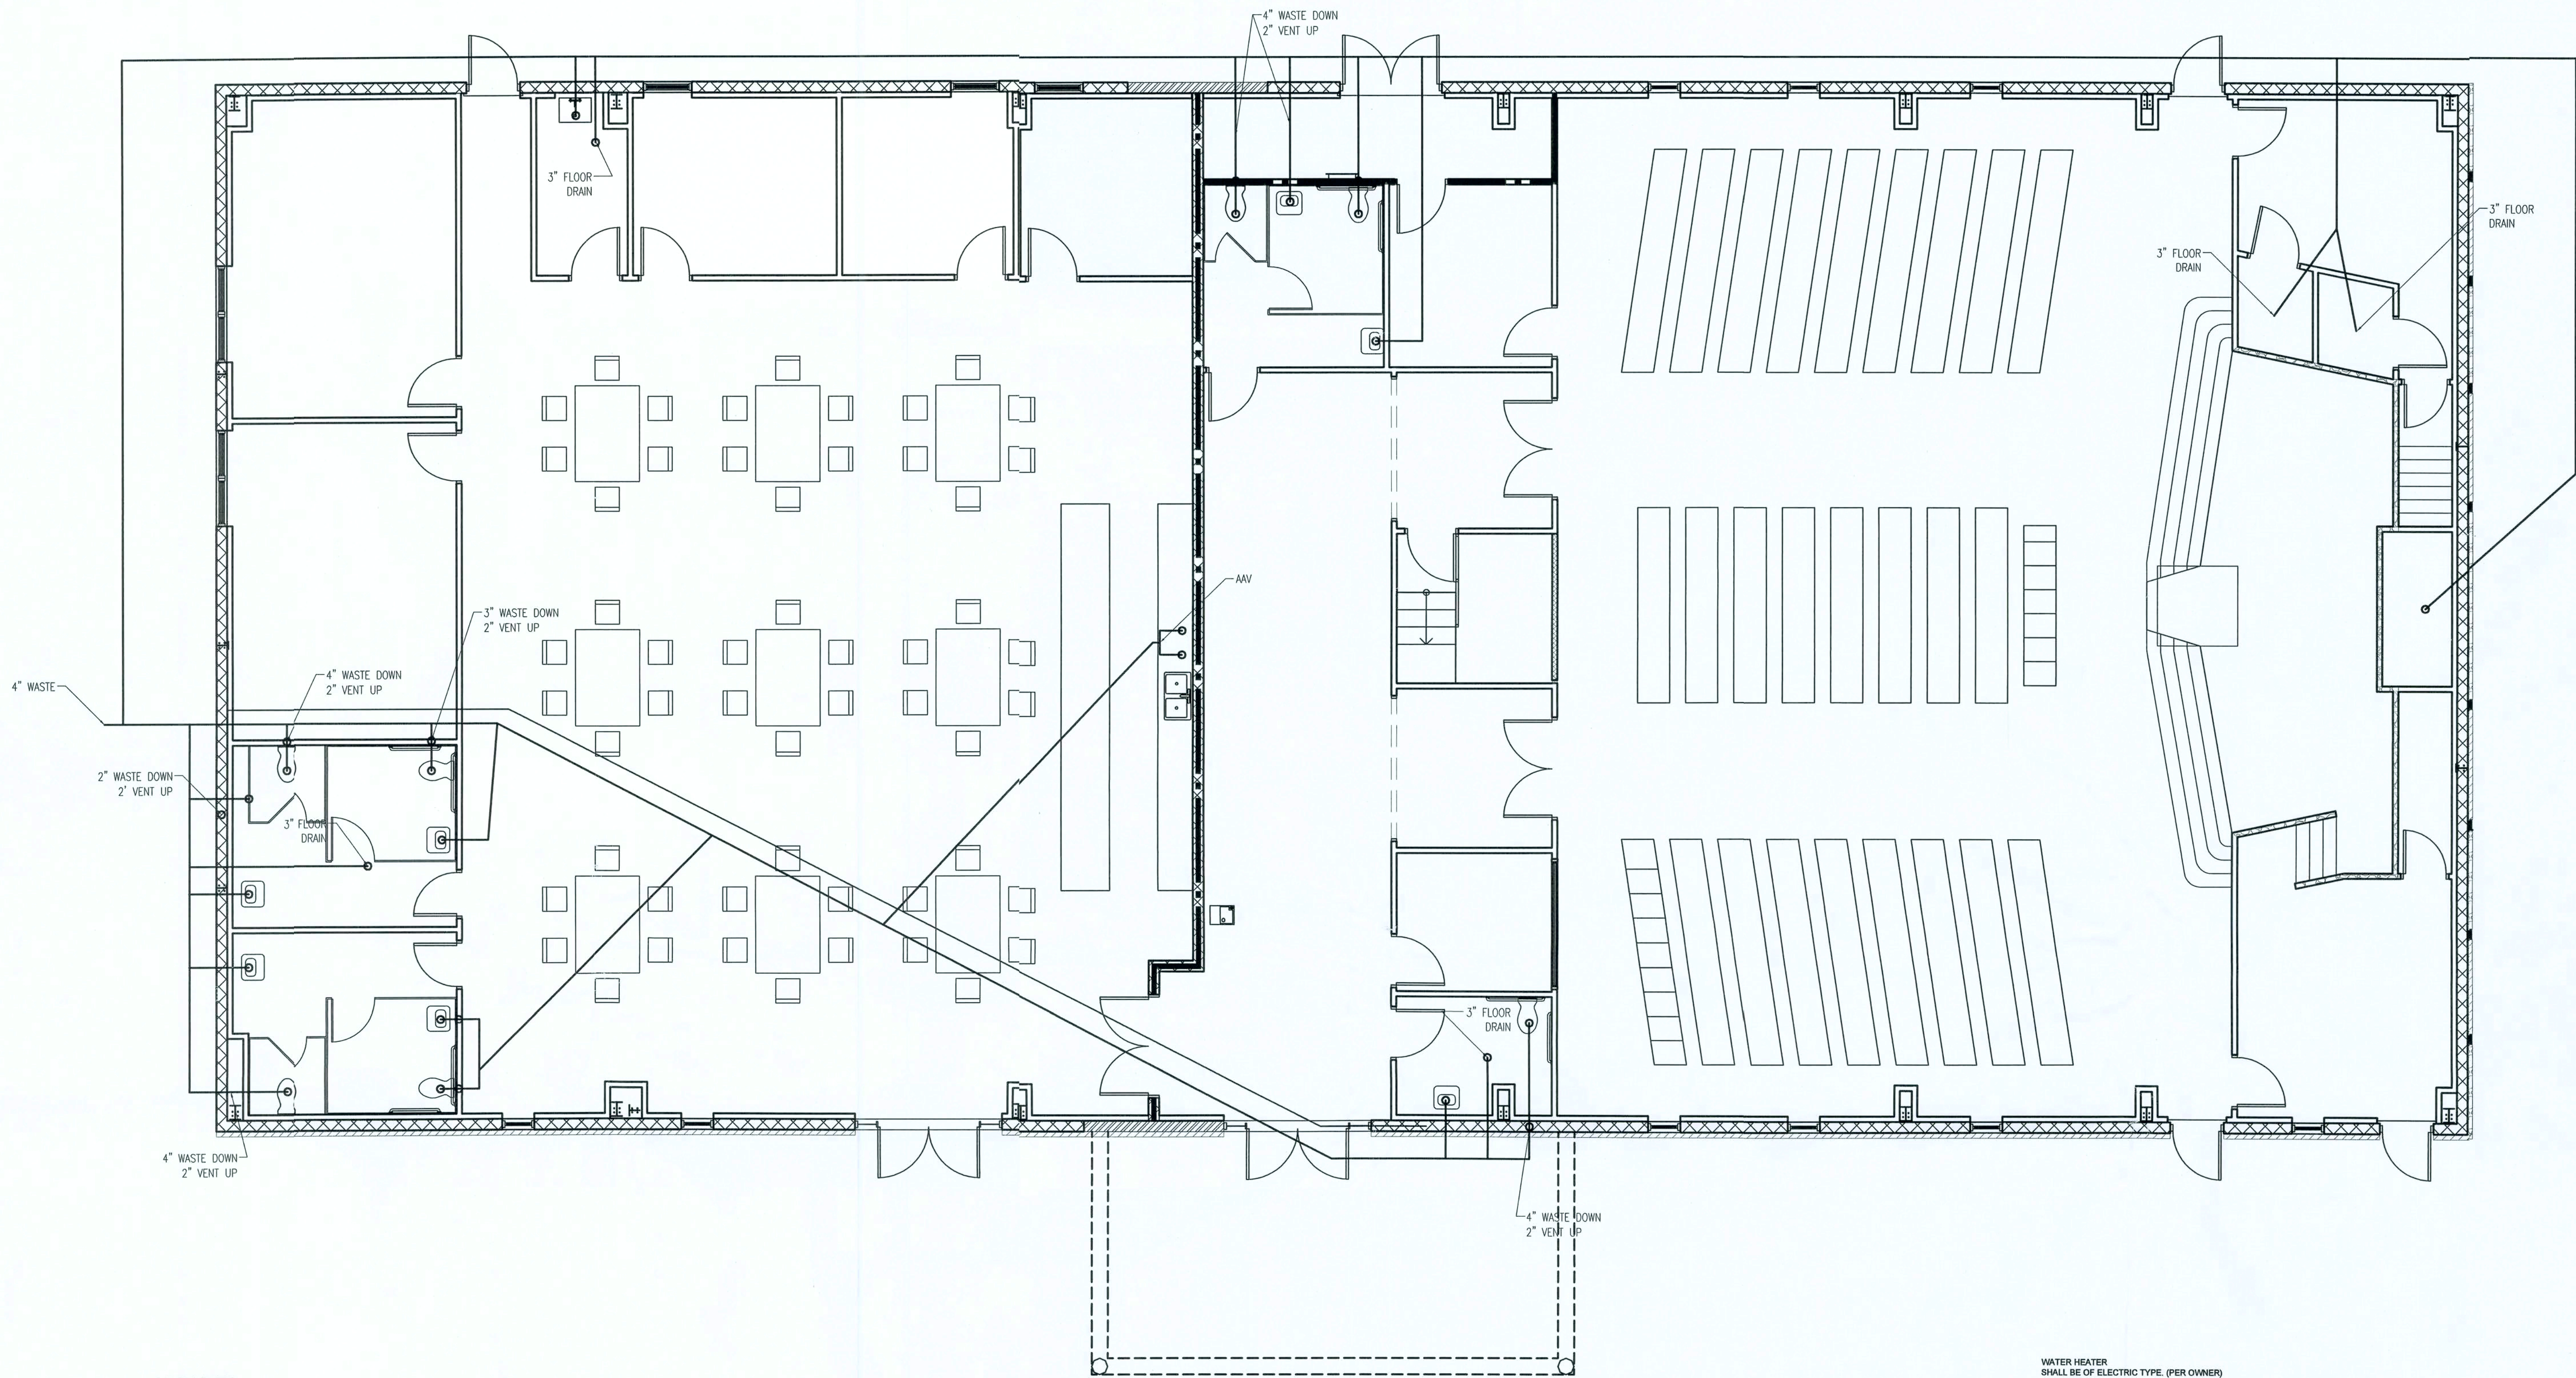


FIXTURES:

F1 = LAVATORY
F2 = WATER CLOSET
F3 = FLOOR DRAIN
F4= SINK
F5 = URINAL
FD = FLOOR DRAIN

NOTES:

1. SOIL PIPING, VENTS, AND STACK TO BE SCH. 40 PVC.
2. ALL AAV (AIR ADMITTANCE VENT) VALVES TO BE ACCESSIBLE IN CABINETS OR BY ACCESS GRILLE FOR MAINTENANCE.
3. ALL WORK TO BE INSPECTED AND TESTED IN ACCORDANCE WITH LOCAL CODES.

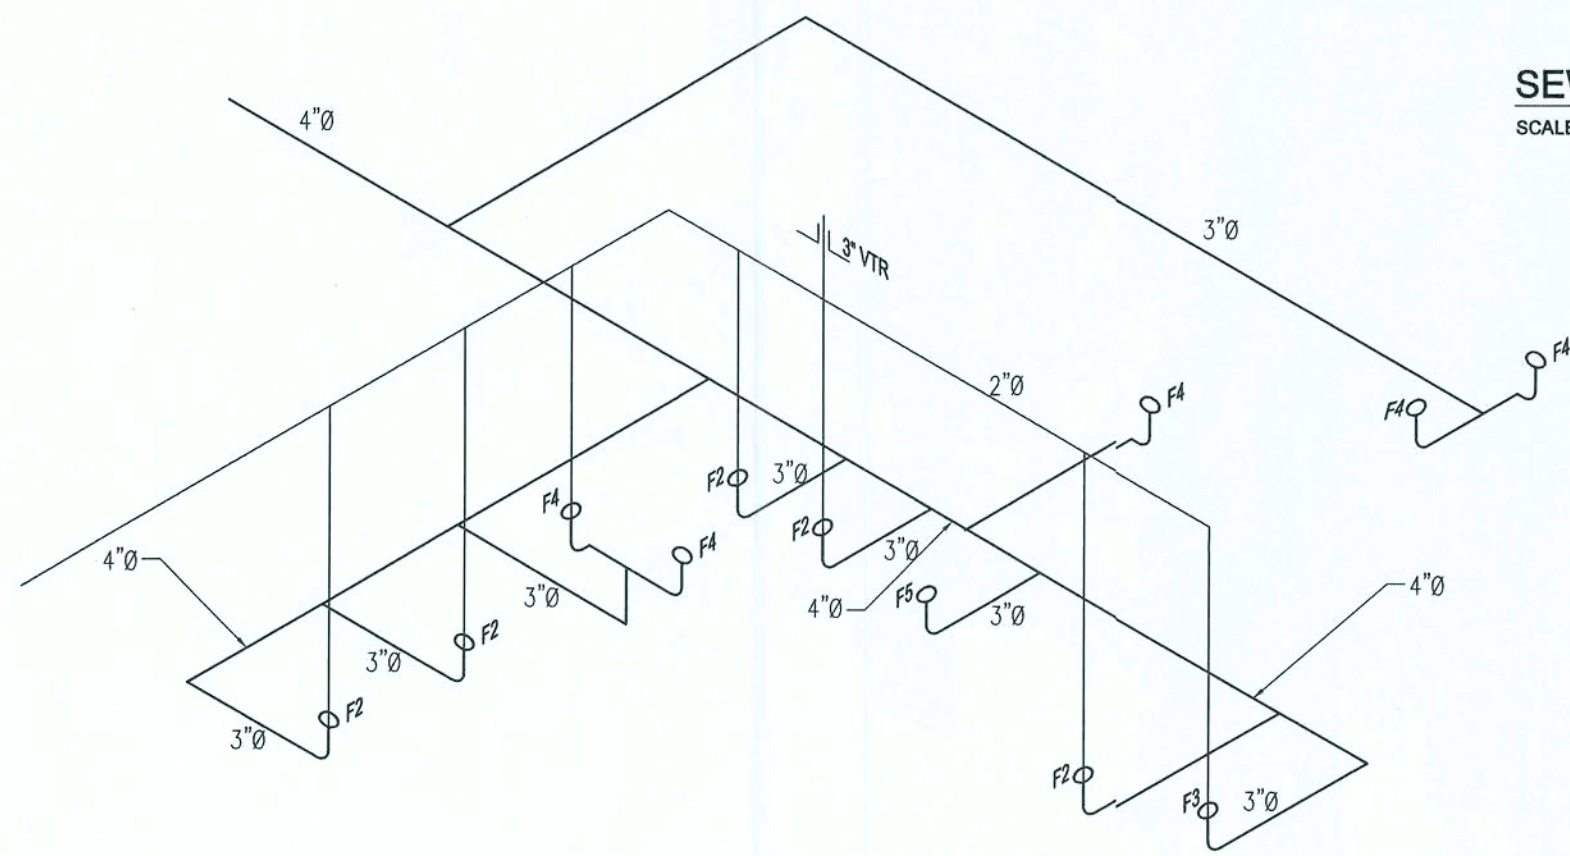

PLUMBING RISER DIAGRAM
SCALE: N.T.S.

SEWER PLAN
SCALE: 1/8" = 1'-0"

1. DRAWINGS ARE DIAGRAMMATIC AND SHALL NOT BE SCALED. REFER TO ARCHITECTURAL PLANS AND ELEVATIONS FOR EXACT LOCATION OF ALL PLUMBING FIXTURES, EQUIPMENT, ETC. PLUMBING CONTRACTOR SHALL FURNISH AND INSTALL ALL ITEMS REQUIRED FOR A COMPLETE AND ACCEPTABLE WORKING INSTALLATION.
2. ALL WORK AND MATERIAL SHALL COMPLY WITH THE NATIONAL, STATE, AND ALL LOCAL CODES AND ORDINANCES HAVING JURISDICTION.
3. THE PLUMBING CONTRACTOR SHALL VISIT THE SITE AND THOROUGHLY FAMILIARIZE HIMSELF WITH ALL EXISTING CONDITIONS. ALL EXECUTION AND BACKFILL AS REQUIRED FOR THIS PHASE OF CONSTRUCTION SHALL BE A PART OF THIS CONTRACT.
4. ALL MATERIAL SHALL BE NEW.
5. ALL WORK SHALL BE PERFORMED BY A LICENSED PLUMBING CONTRACTOR IN A FIRST CLASS WORKMANLIKE MANNER. THE COMPLETED SYSTEM SHALL BE FULLY OPERATIVE AND ACCEPTED BY ENGINEER/ARCHITECT.
6. ALL REQUIRED INSURANCE SHALL BE PROVIDED FOR PROTECTION AGAINST PUBLIC LIABILITY OR PROPERTY DAMAGE FOR THE DURATION OF THE WORK.
7. THE PLUMBING CONTRACTOR SHALL SECURE AND PAY ALL PERMIT FEES, INSPECTIONS, AND TESTS.
8. ALL WORK SHALL BE COORDINATED WITH OTHER TRADES TO AVOID INTERFERENCE WITH THE PROGRESS OF CONSTRUCTION.
9. THE PLUMBING CONTRACTOR SHALL GUARANTEE ALL MATERIAL AND WORKMANSHIP FREE FROM DEFECTS FOR A PERIOD OF NOT LESS THAN (1) ONE YEAR FROM DATE OF ACCEPTANCE. CORRECTION OF ANY DEFECTS SHALL BE COMPLETED WITHOUT ADDITIONAL CHARGES AND SHALL INCLUDE REPLACEMENT OR REPAIR OF ANY OTHER PHASE IN THE INSTALLATION WHICH MAY HAVE BEEN DAMAGED THEREBY.
10. VERIFY LOCATION, SIZE AND INVERTS OF ALL EXISTING UTILITIES PRIOR TO START OF CONSTRUCTION. ADVISE ENGINEER/ARCHITECT OF ANY DISCREPANCIES.
11. ALL FIXTURES SHALL BE PROVIDED WITH READILY ACCESSIBLE STOPS.
12. WATER PIPING SHALL BE CPVC.
13. SOIL, WASTE, AND VENT PIPING SHALL BE PVC SCHEDULE 40. WASTE AND VENT PIPING ABOVE SLAB SHALL BE PVC.
14. AIR CONDITIONING CONDENSATE DRAIN PIPING SHALL BE PVC SCHEDULE 40. INSULATE ALL CONDENSATE PIPING EXCEPT EXTERNAL PIPING. ALL PIPING TO BE INSTALLED PER LOCAL CODE.
15. FURNISH AND INSTALL APPROVED AIR CHAMBERS AT EACH PLUMBING FIXTURE AND PDI APPROVED SHOCK ARRESTERS ON MAIN LINE AND RISERS.
16. PROVIDE CHROME PLATED COMBINATION COVERED PLATE AND CLEANOUT PLUG FOR ALL WALL CLEANOUTS, JOSAM #58890.
17. INSULATE LINES AS FOLLOWS:
a. WATER SUPPLY AND RETURNS: 1" THICK ARMAFLEX
b. CONDENSATE DRAIN: 3/4" THICK ARMAFLEX

WATER HEATER
SHALL BE OF ELECTRIC TYPE, (PER OWNER)

WC
SHALL BE AN AMERICAN STANDARD MODEL NEW CADET II AQUAMETER 2174.139 ELONGATED TANK
1.6 GPF, VITREOUS CHINA, SIPHON ACTION BOWL, CLOSE-COUPLED TANK, SPEED CONNECT
TANK/BOWL COUPLING SYSTEM TOILET AND AN OLSONITE #95 OPEN SEAT LESS COVER.

HC WC
SHALL BE AN AMERICAN STANDARD MODEL NEW CADET II AQUAMETER 2216.143 ELONGATED 18"
HIGH, 1.6 GPF, VITREOUS CHINA, SIPHON ACTION BOWL, CLOSE-COUPLED TANK, SPEED CONNECT
TANK/BOWL COUPLING SYSTEM TOILET AND AN OLSONITE #95 OPEN SEAT LESS COVER.

KITCHEN SINK
SHALL BE ELKAY LUSTERTONE MODEL DLH-2222-10-C SINGLE BOWL, STAINLESS STEEL
SELF-RIMMING SINK WITH LK432 H-ARC FAUCET TO INCLUDE AN OMNI PRESSURE COMPENSATING
2.0 GPM FLOW RESTRICTOR.

JANITOR SINK
SHALL BE AN AMERICAN STANDARD MODEL FLORWELL 7740.029 ENAMELED CAST IRON SERVICE
SINK WITH 7745.011 REMOVABLE VINYL-COATED RIM GUARD, 7721.036 DRAIN WITH STRAINER AND
7298.162 HERITAGE SERVICE SINK FITTING FAUCET TO INCLUDE AN OMNI PRESSURE
COMPENSATING VANDAL RESISTANT 2.0 GPM FLOW RESTRICTOR WITH BUCKET HOOKS.

LAV
SHALL BE AN AMERICAN STANDARD MODEL RONDALYN 0491.019 VITREOUS CHINA SELF-RIMMING
STYLE CLASSIC ROUND SHAPE, PROVIDE A 5401.158 HERITAGE CENTERSET FAUCET TO INCLUDE
AN OMNI PRESSURE COMPENSATING 0.5 GPM FLOW RESTRICTOR

HC LAV
SHALL BE AN AMERICAN STANDARD MODEL RONDALYN 0491.019 VITREOUS CHINA SELF-RIMMING
STYLE CLASSIC ROUND SHAPE, PROVIDE A 5401.170H HERITAGE CENTERSET FAUCET WITH 4" VARI-
BLADE HANDLES TO INCLUDE AN OMNI PRESSURE COMPENSATING 0.5 GPM FLOW RESTRICTOR
AQUASEAL VALVE AND CHROME FINISH. GRIP DRAIN OFFSET PERFORATED WHEELCHAIR
LAVATORY DRAIN ASSEMBLY WITH 1-1/2" TALLPIECE, MCGUIRE #159VC.

EWV
SHALL BE AN OASIS MODEL PLF#WMEE, 8.0 GPM, 4.8 FLA AT 120 VOLT WITH A 1/5 HP COMPRESSOR

HOSE BIBB
SHALL BE A JOSAM 71000-65 SERIES CAST BRONZE BOX TYPE NON-FREEZE VANDAL PROOF WALL
HYDRANT WITH COVER AND CONTROL KEY.

- NOTES:
1. ALL PLUMBING FIXTURES SHALL BE AS SPECIFIED OR APPROVED EQUAL.
 2. PROVIDE ANGLE STOPS ON ALL WATER SERVICE LINES TO FIXTURE FOR INDIVIDUAL SHUT-OFF.
 3. ALL HANDICAP PLUMBING FIXTURES SHALL BE INSTALLED PER THE LATEST ADA REQUIREMENTS.

ISSUED FOR APPROVAL

9/27/07

REVISION NOTES	
REV #	DATE
###	###

P.O. Box 187
130 West Howard Street
Live Oak, FL 32064
Phone: (386) 362-3678
Fax: (386) 362-6133
Auth. # 51942

G.G.
STRUCTURAL/CIVIL ENGINEER GARY GILL, P.E. # 51942

7TH DAY ADVENTIST CHURCH
NEW WORSHIP CENTER
COLUMBIA COUNTY, FLORIDA

PLUMBING PLAN

PROJECT NUMBER	PF06-193S
DRAWN BY	-
CHECKED BY	G.G.
P-2	

SHEET 18 OF 16

7th ADVENTIST CHURCH

NEW WORSHIP CENTER

COLUMBIA COUNTY, FLORIDA



APPLICABLE CODES
2004 FLORIDA BUILDING CODE
2002 NATIONAL ELECTRIC CODE (NFPA 70)
2004 FLORIDA PLUMBING CODE
2004 FLORIDA MECHANICAL CODE
2004 FLORIDA FIRE PROTECTION CODE
(INCLUDES 2004 LIFE SAFETY CODE)

OCCUPANCY CLASS
ASSEMBLY (A-3)
BUSINESS (PROFESSIONAL SERVICES)

OCCUPANCY LOADING / EGRESS REQUIREMENTS
ASSEMBLY (A-3) FIXED SEATING = 168, UNCONCENTRATED SEATING = 40
BUSINESS (PROFESSIONAL SERVICES) = 45

TYPE OF CONSTRUCTION
TYPE II

CONSTRUCTION DOCUMENTS
THE CUSTOMER IS RESPONSIBLE FOR DELIVERING THE REQUIRED SETS OF CONSTRUCTION DOCUMENTS TO THE PERMIT ISSUING AUTHORITIES, FOR THE ISSUANCE OF CONSTRUCTION PERMITS. THE CONTRACTOR SHALL REVIEW THE CONSTRUCTION DOCUMENTS AND VERIFY ALL DIMENSIONS. ANY DISCREPANCIES SHALL BE REPORTED TO YOUR SALES REPRESENTATIVE PRIOR TO THE COMMENCEMENT OF ANY WORK OR FABRICATION OF ANY MATERIALS.

DO NOT SCALE OFF THESE PLANS
AMPLE DIMENSIONS ARE SHOWN ON THE PLANS TO LOCATE ALL ITEMS. SIMPLE ARITHMETIC MAY BE USED TO DETERMINE THE LOCATIONS OF THOSE ITEMS NOT DIMENSIONED.




P.O. Box 187
130 West Howard Street
Live Oak FL, 32064
Phone: (386) 362-3678
Fax: (386) 362-6133
Gary Gill, PE 51942
Auth. # 9461

BUILDING AREA	
BUILDING AREA	= 9100 S.F.
COMMON AREA & CLASS ROOMS	= 4377 S.F.
SANCTUARY & ENTRANCE AREA	= 4416 S.F.
FRONT PORCH	= 450 S.F.
AREA INDEX:	
HEATED:	=1538.92 S.F.
TOTAL:	=4065.64 S.F.

Sheet List Table

- A-1.0 FLOOR PLAN
- A-1.1 FLOOR PLAN SCHEDULES
- A-1.2 FINISH PLAN
- A-2.0 ELEVATIONS
- A-2.1 ELEVATIONS
- A-3.0 REFLECTED CEILING PLAN
- A-4.0 LIFE SAFETY
- S-1 FOUNDATION PLAN
- S-2.0 SECTIONS
- S-2.1 DETAILS
- M-1 MECHANICAL PLAN
- E-1.0 LIGHTING PLAN
- E-1.1 POWER PLAN
- E 1.2 ELECTRICAL SCHEDULES AND NOTES
- P-1 WATER SUPPLY PLAN
- P-2 PLUMBING PLAN

7/5/07

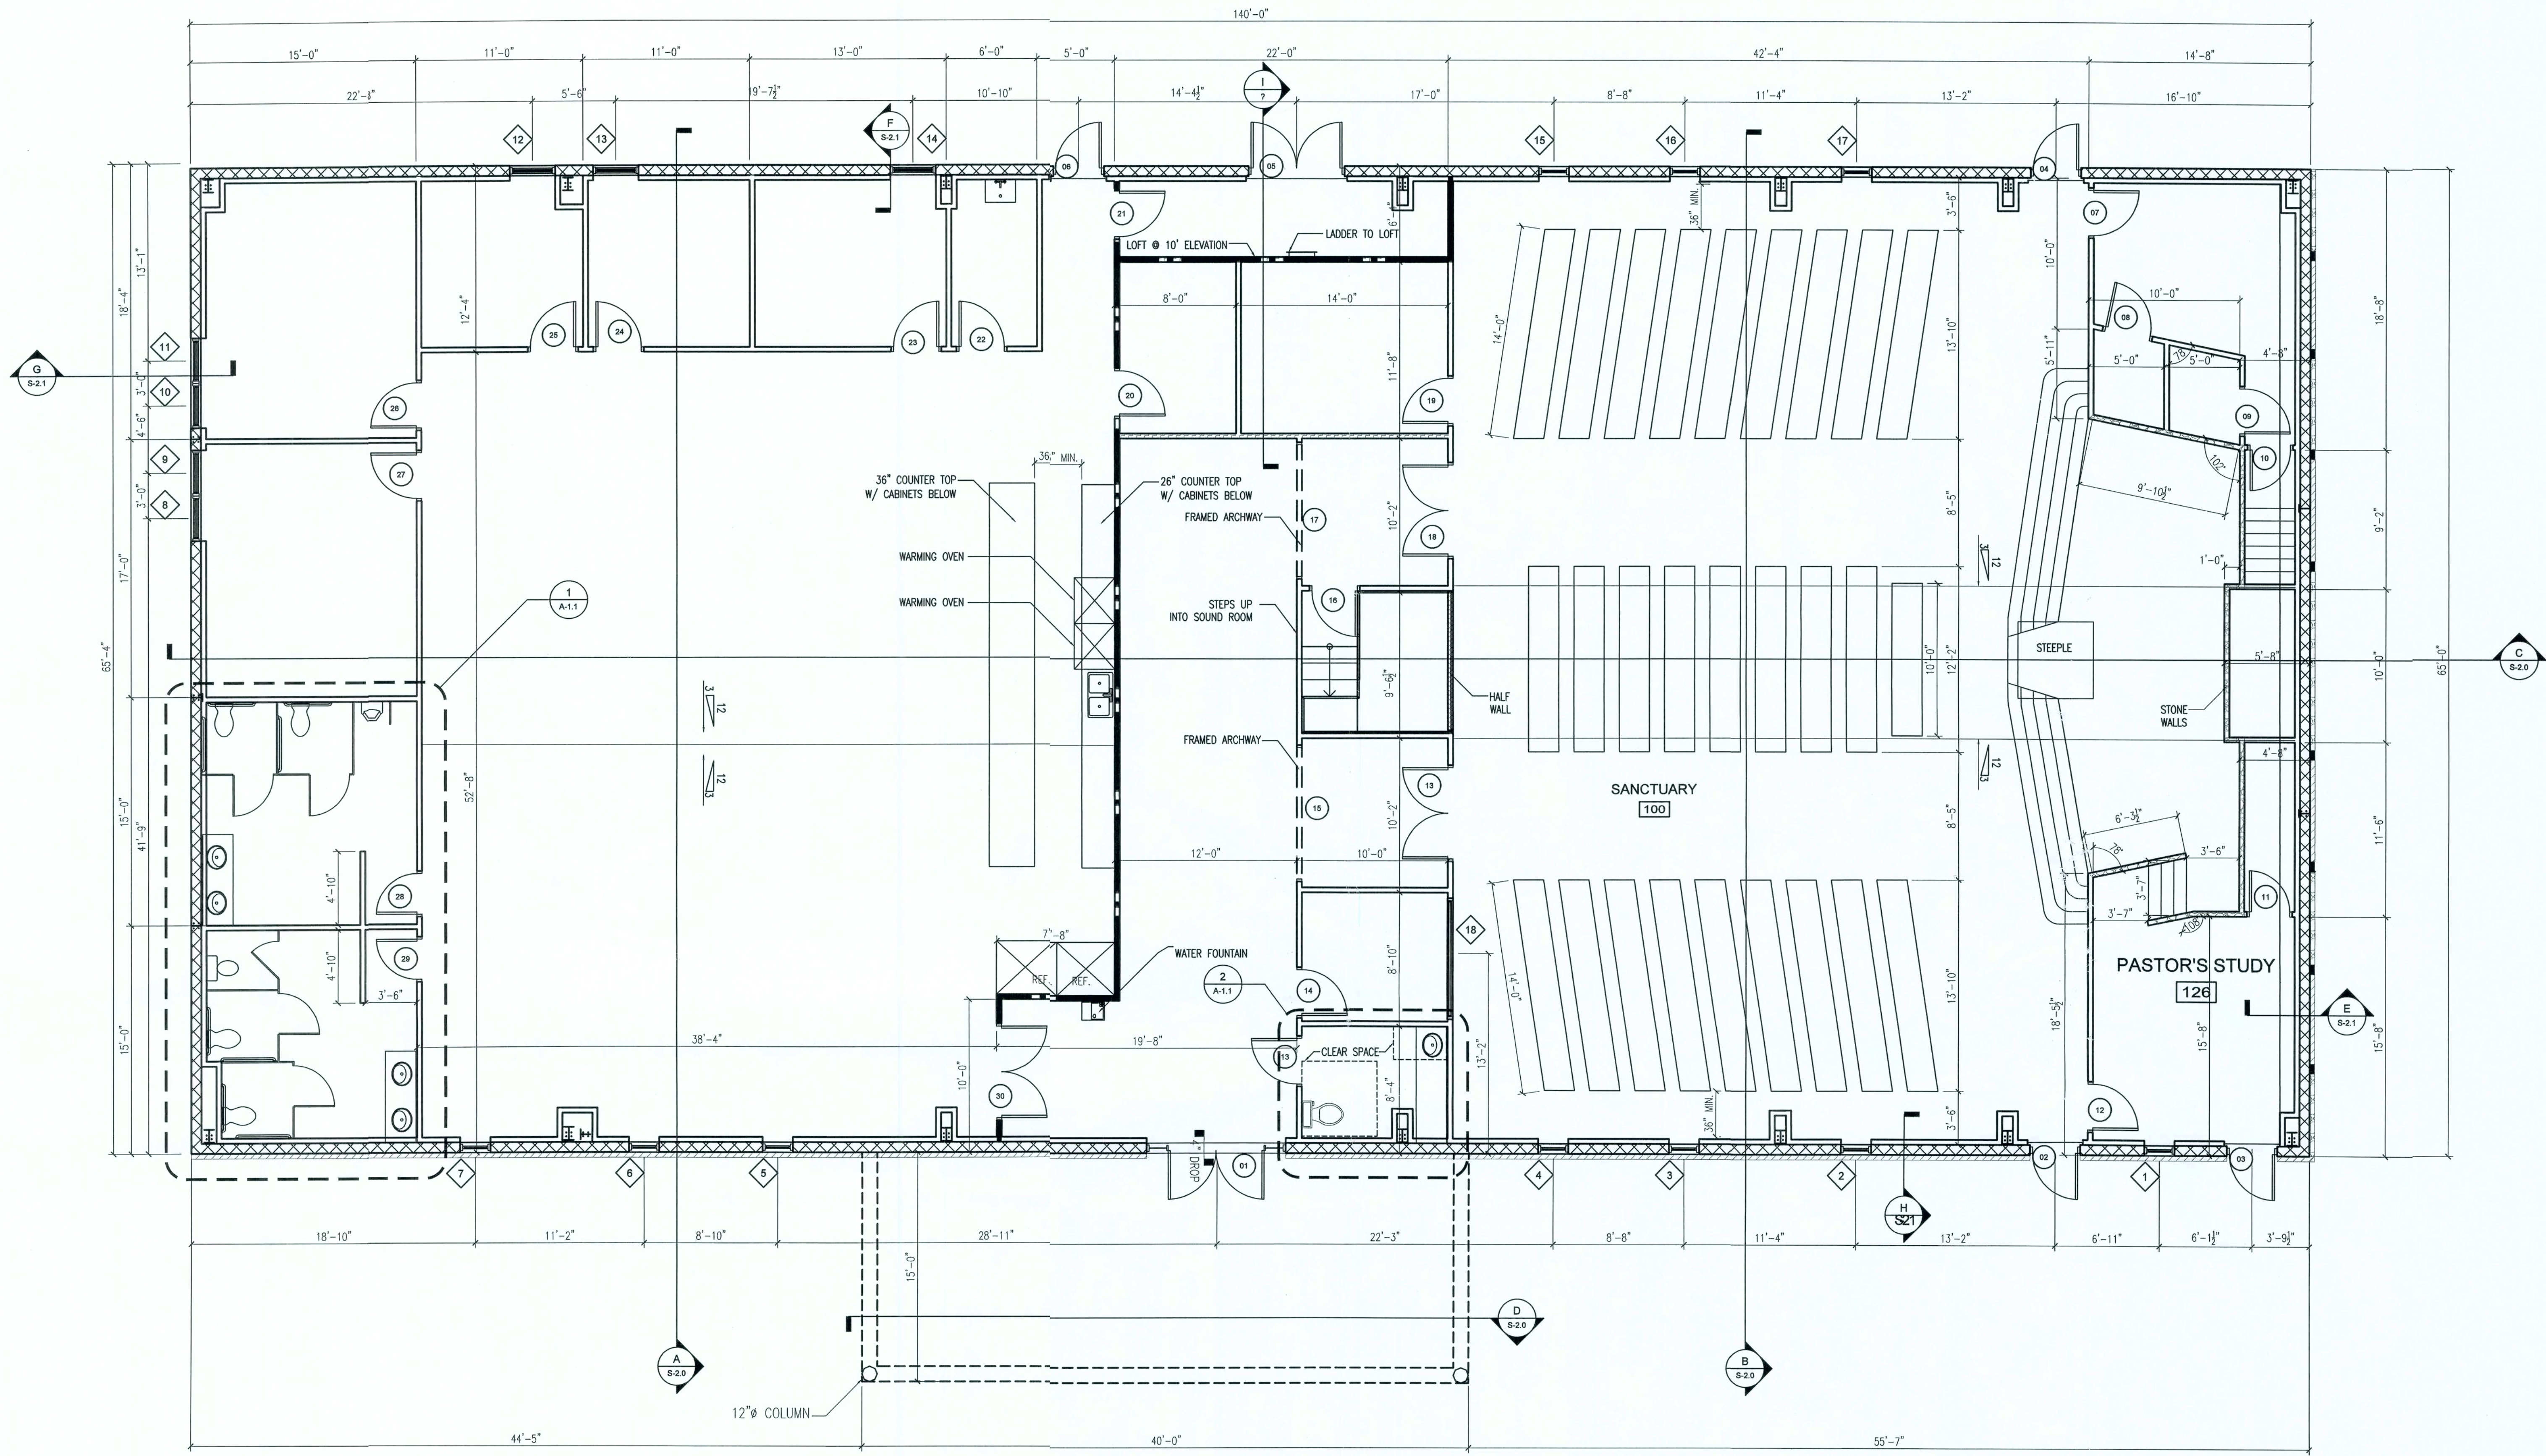

WALL LEGEND	
	= INTERIOR WALLS
	3 3/8" METAL STUDS
	42" A.F.F. 3 3/8" METAL STUDS
	= 1 HOUR FIRE WALL
	= INTERIOR BEARING WALL
	= DECORATIVE STONE WALL
	= DECORATIVE BRICK WALL
	= 8" METAL WALL

BUILDING AREA	
BUILDING AREA	= 9100 S.F.
COMMON AREA & CLASS ROOMS	= 4377 S.F.
SANCTUARY & ENTRANCE AREA	= 4416 S.F.
FRONT PORCH	= 450 S.F.

FLOOR PLAN
SCALE: 3/16" = 1'-0"

ISSUED FOR APPROVAL

REV #	DATE	REVISION NOTES
1	10-20-06	ISSUED FOR CONSTRUCTION

P.O. Box 187
130 West Howard Street
Live Oak FL 32064
Phone: (386) 362-3678
Fax: (386) 362-6133
Auth. # 9461

JG
STRUCTURAL CIVIL ENGINEERS



7th ADVENTIST CHURCH
NEW WORSHIP CENTER
COLUMBIA COUNTY, FLORIDA

FLOOR PLAN

PROJECT NUMBER	PF06-193S
DRAWN BY	D. PRICE
CHECKED BY	G.G.

A-1.0


7/15/07

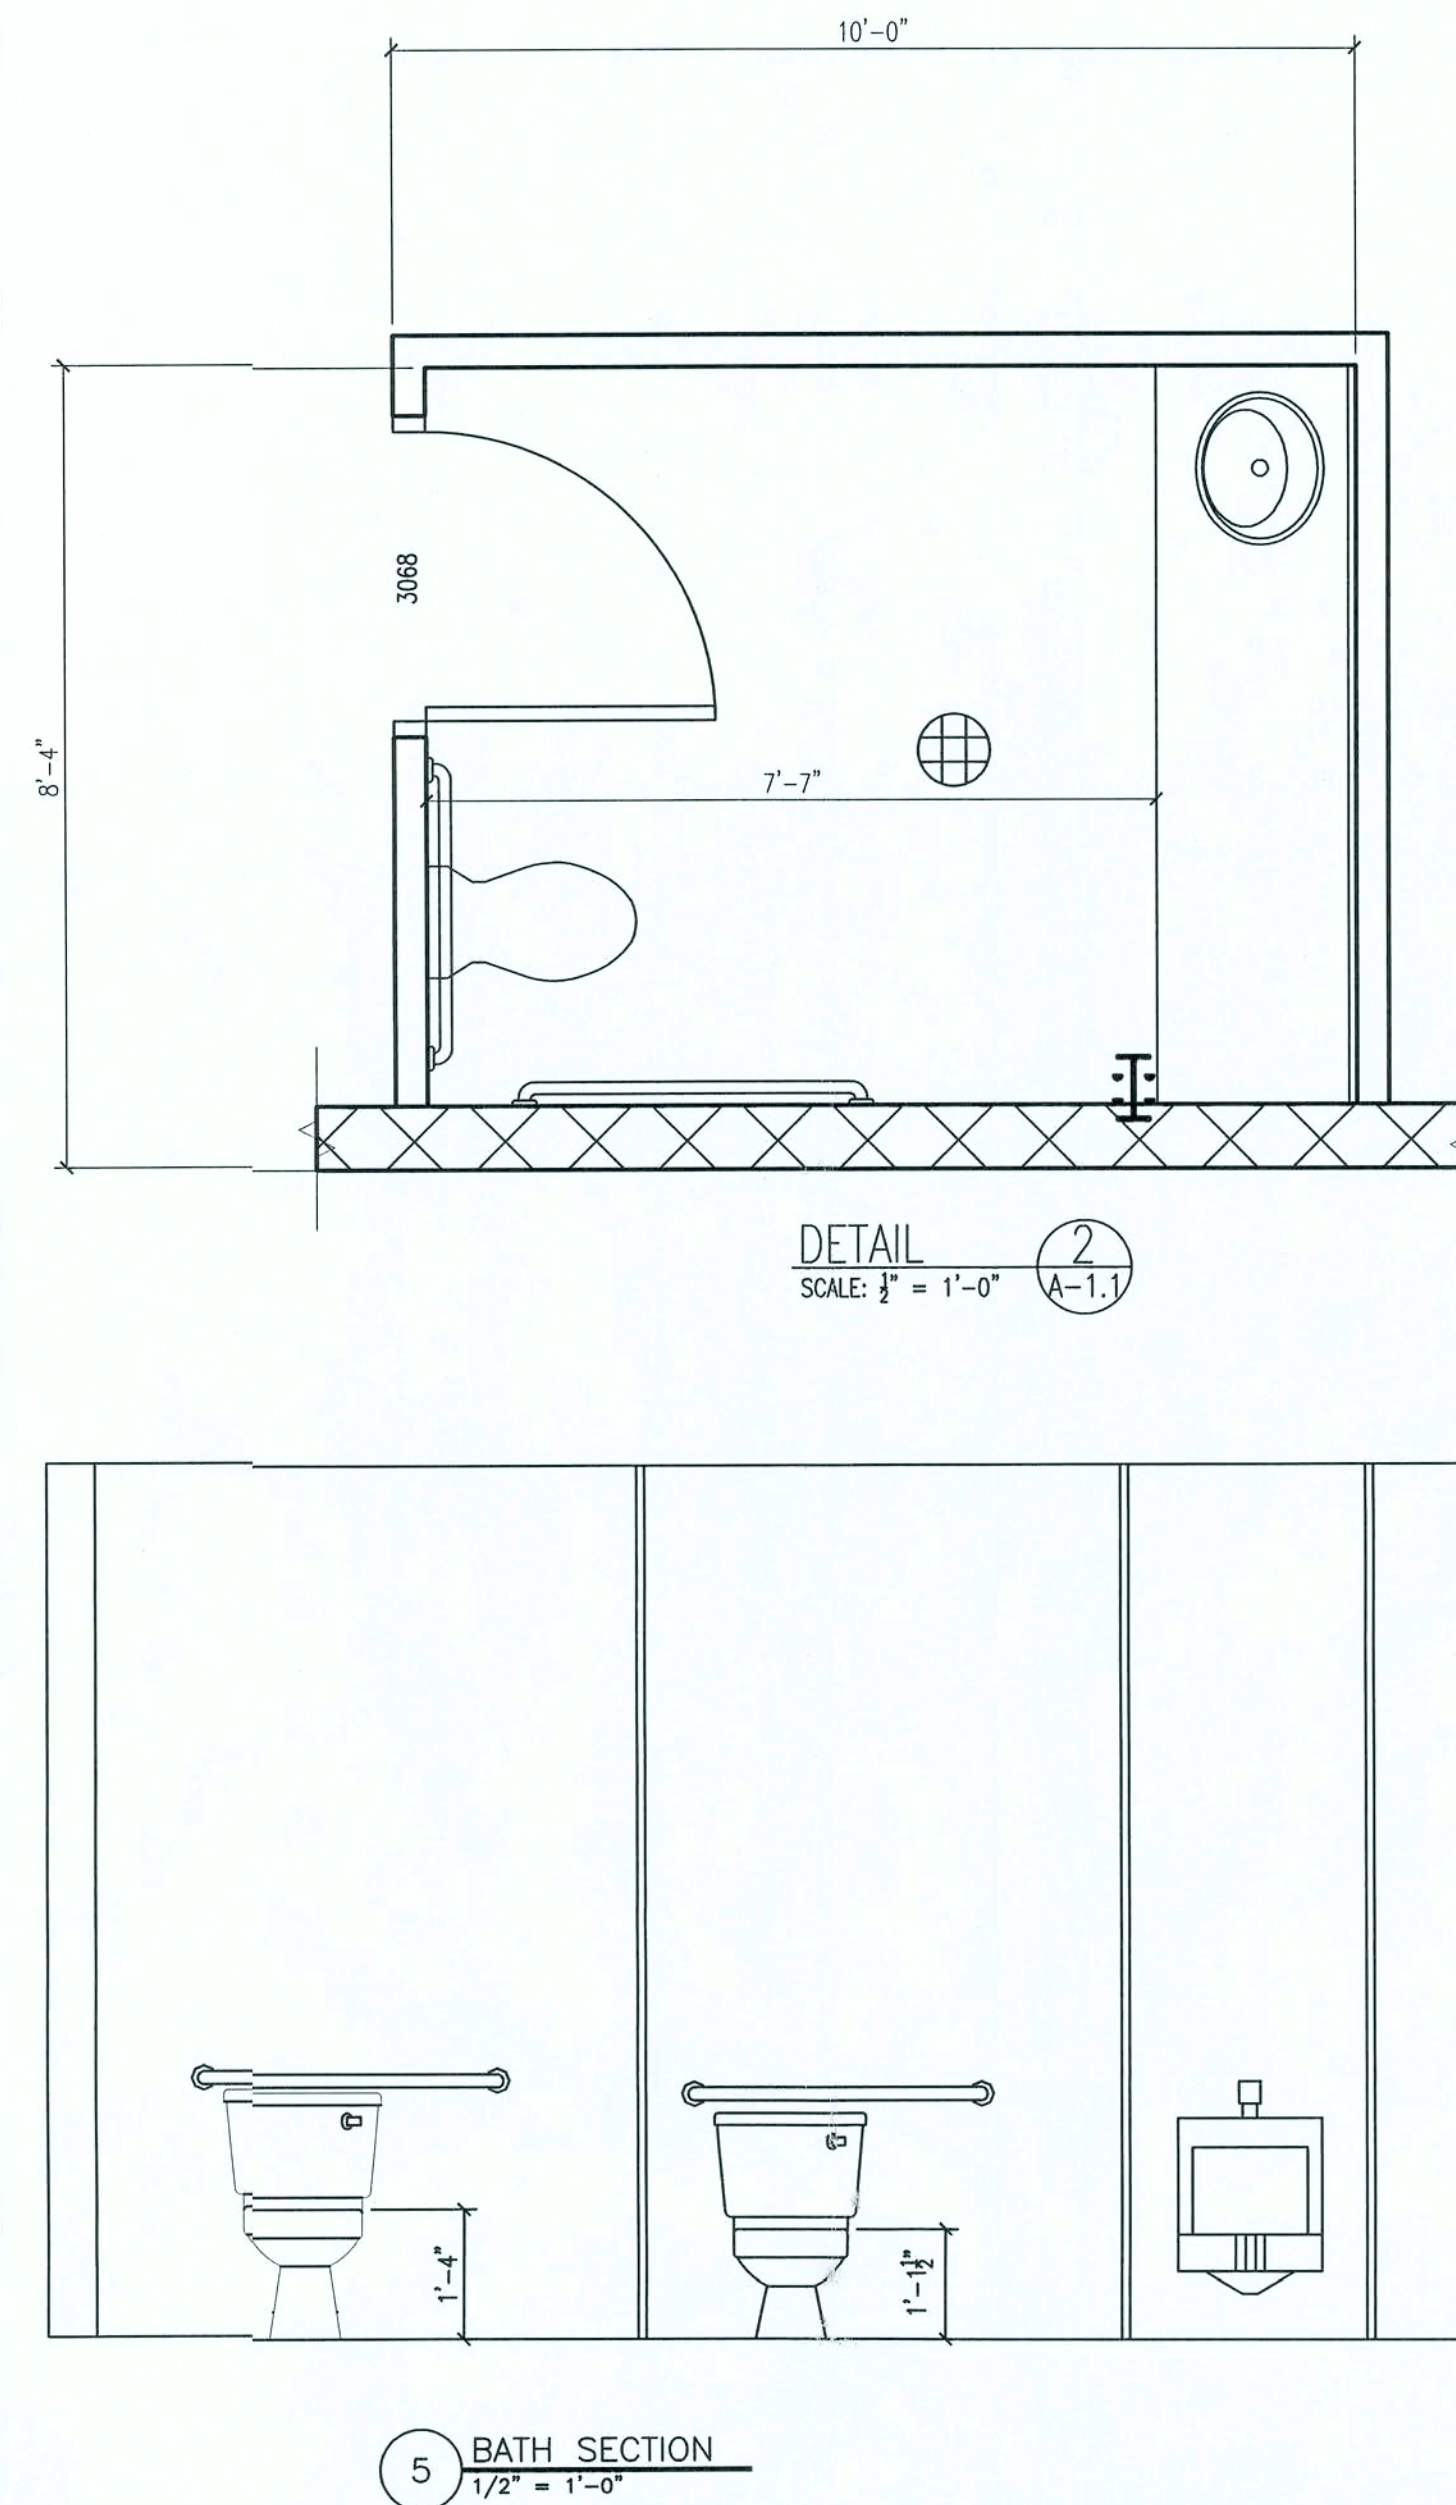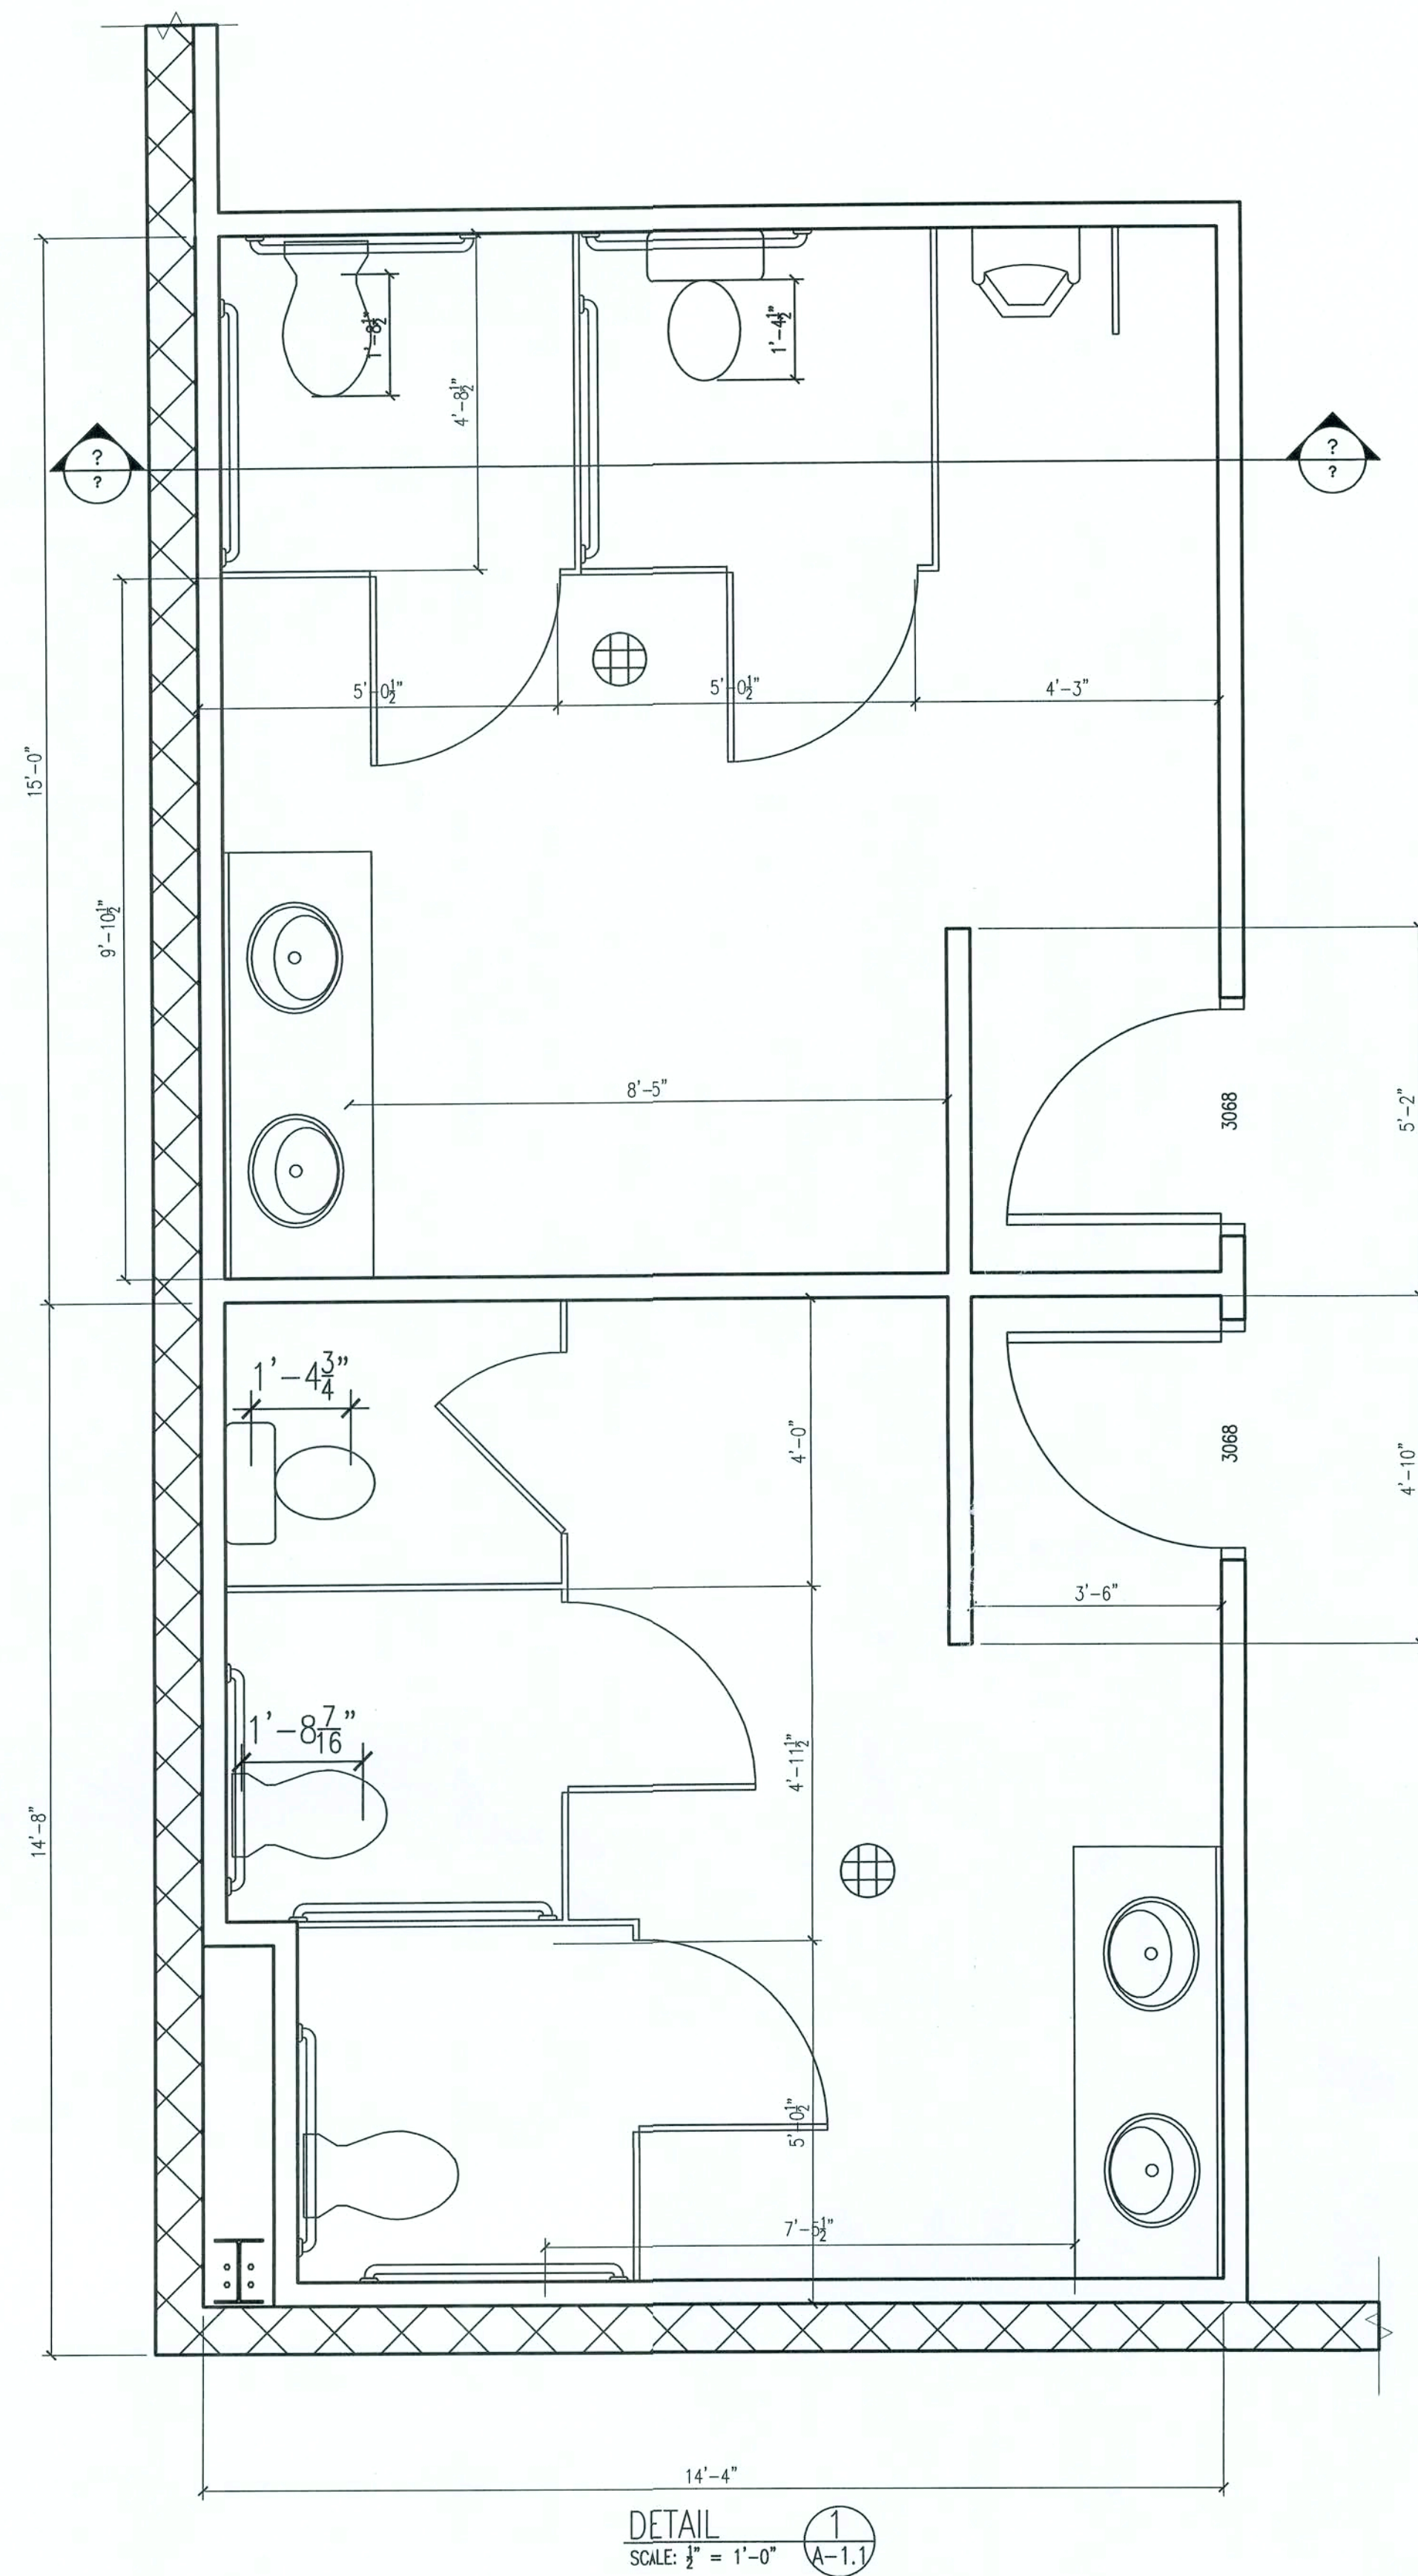

- (1) DOORS:
DOORWAYS SHALL HAVE A MINIMUM CLEAR OPENING OF 32" WITH THE DOOR OPEN 90 DEGREES, MEASURED BETWEEN THE FACE OF THE DOOR AND THE STOP.
- (2) DOOR HARDWARE:
HANDLES, PULLS, LATCHES, LOCKS, AND OTHER OPERATING DEVICES ON ACCESSIBLE DOORS SHALL HAVE A SHAPE THAT IS EASY TO GRASP WITH ONE HAND AND DOES NOT REQUIRE TIGHT GRASPING, TIGHT PINCHING, OR TWISTING OF THE WRIST TO OPERATE. LEVER-OPERATED MECHANISM, PUSH TYPE MECHANISM, AND U-SHAPED HANDLES ARE ACCEPTABLE DESIGNS.
- (3) DRINKING FOUNTAINS AND WATER COOLERS:
SPOUTS SHALL BE NO HIGHER THAN 30" MEASURED FROM THE FLOOR OR GROUND SURFACE TO THE SPOUT LOCATION.
FOR SIZE AND ARRANGEMENT SEE ADA TOILET STALL DIAGRAM.
- (5) LAVATORIES AND MIRRORS:
LAVATORIES SHALL BE MOUNTED WITH THE RIM OR COUNTER SURFACE NO HIGHER THAN 34" ABOVE THE FINISHED FLOOR. PROVIDE A CLEARANCE OF AT LEAST 29" FROM THE FLOOR TO THE BOTTOM APRON.
- (4) TOILET STALL:
HOT WATER AND DRAIN PIPES SHALL BE INSULATED OR OTHERWISE COVERED. FAUCETS SHALL BE LEVER-OPERATED, PUSH-TYPE, AND ELECTRONICALLY CONTROLLED MECHANISMS ARE EXAMPLES OF ACCEPTABLE DESIGNS. MIRRORS SHALL BE MOUNTED WITH THE BOTTOM OF THE REFLECTING SURFACE NO HIGHER THAN 40" FROM FLOOR.
- (6) RAMPS:
THE LEAST POSSIBLE SLOPE SHALL BE USED FOR ANY RAMP. THE MAXIMUM SLOPE OF A RAMP IN NEW CONSTRUCTION SHALL BE 1:12. THE LANDING LENGTH SHALL BE A MINIMUM OF 60" CLEAR. HANDRAILS SHALL BE PROVIDED ALONG BOTH SIDES OF RAMP SEGMENTS. THE CLEAR SPACE BETWEEN THE HANDRAIL AND THE WALL SHALL BE 1 1/2". GRIPPING SURFACES SHALL BE CONTINUOUS. THE TOP OF HANDRAILS GRIPPING SURFACES SHALL BE MOUNTED BETWEEN 30" AND 34" ABOVE RAMP SURFACE.
- (7) CONTROLS AND OPERATING MECHANISMS:
CONTROLS AND MECHANISMS SHALL BE OPERATED BY ONE HAND AND SHALL REQUIRE TIGHT GRASPING, PINCHING, OR TWISTING OF WRIST.

ISSUED FOR APPROVAL

9/5/07

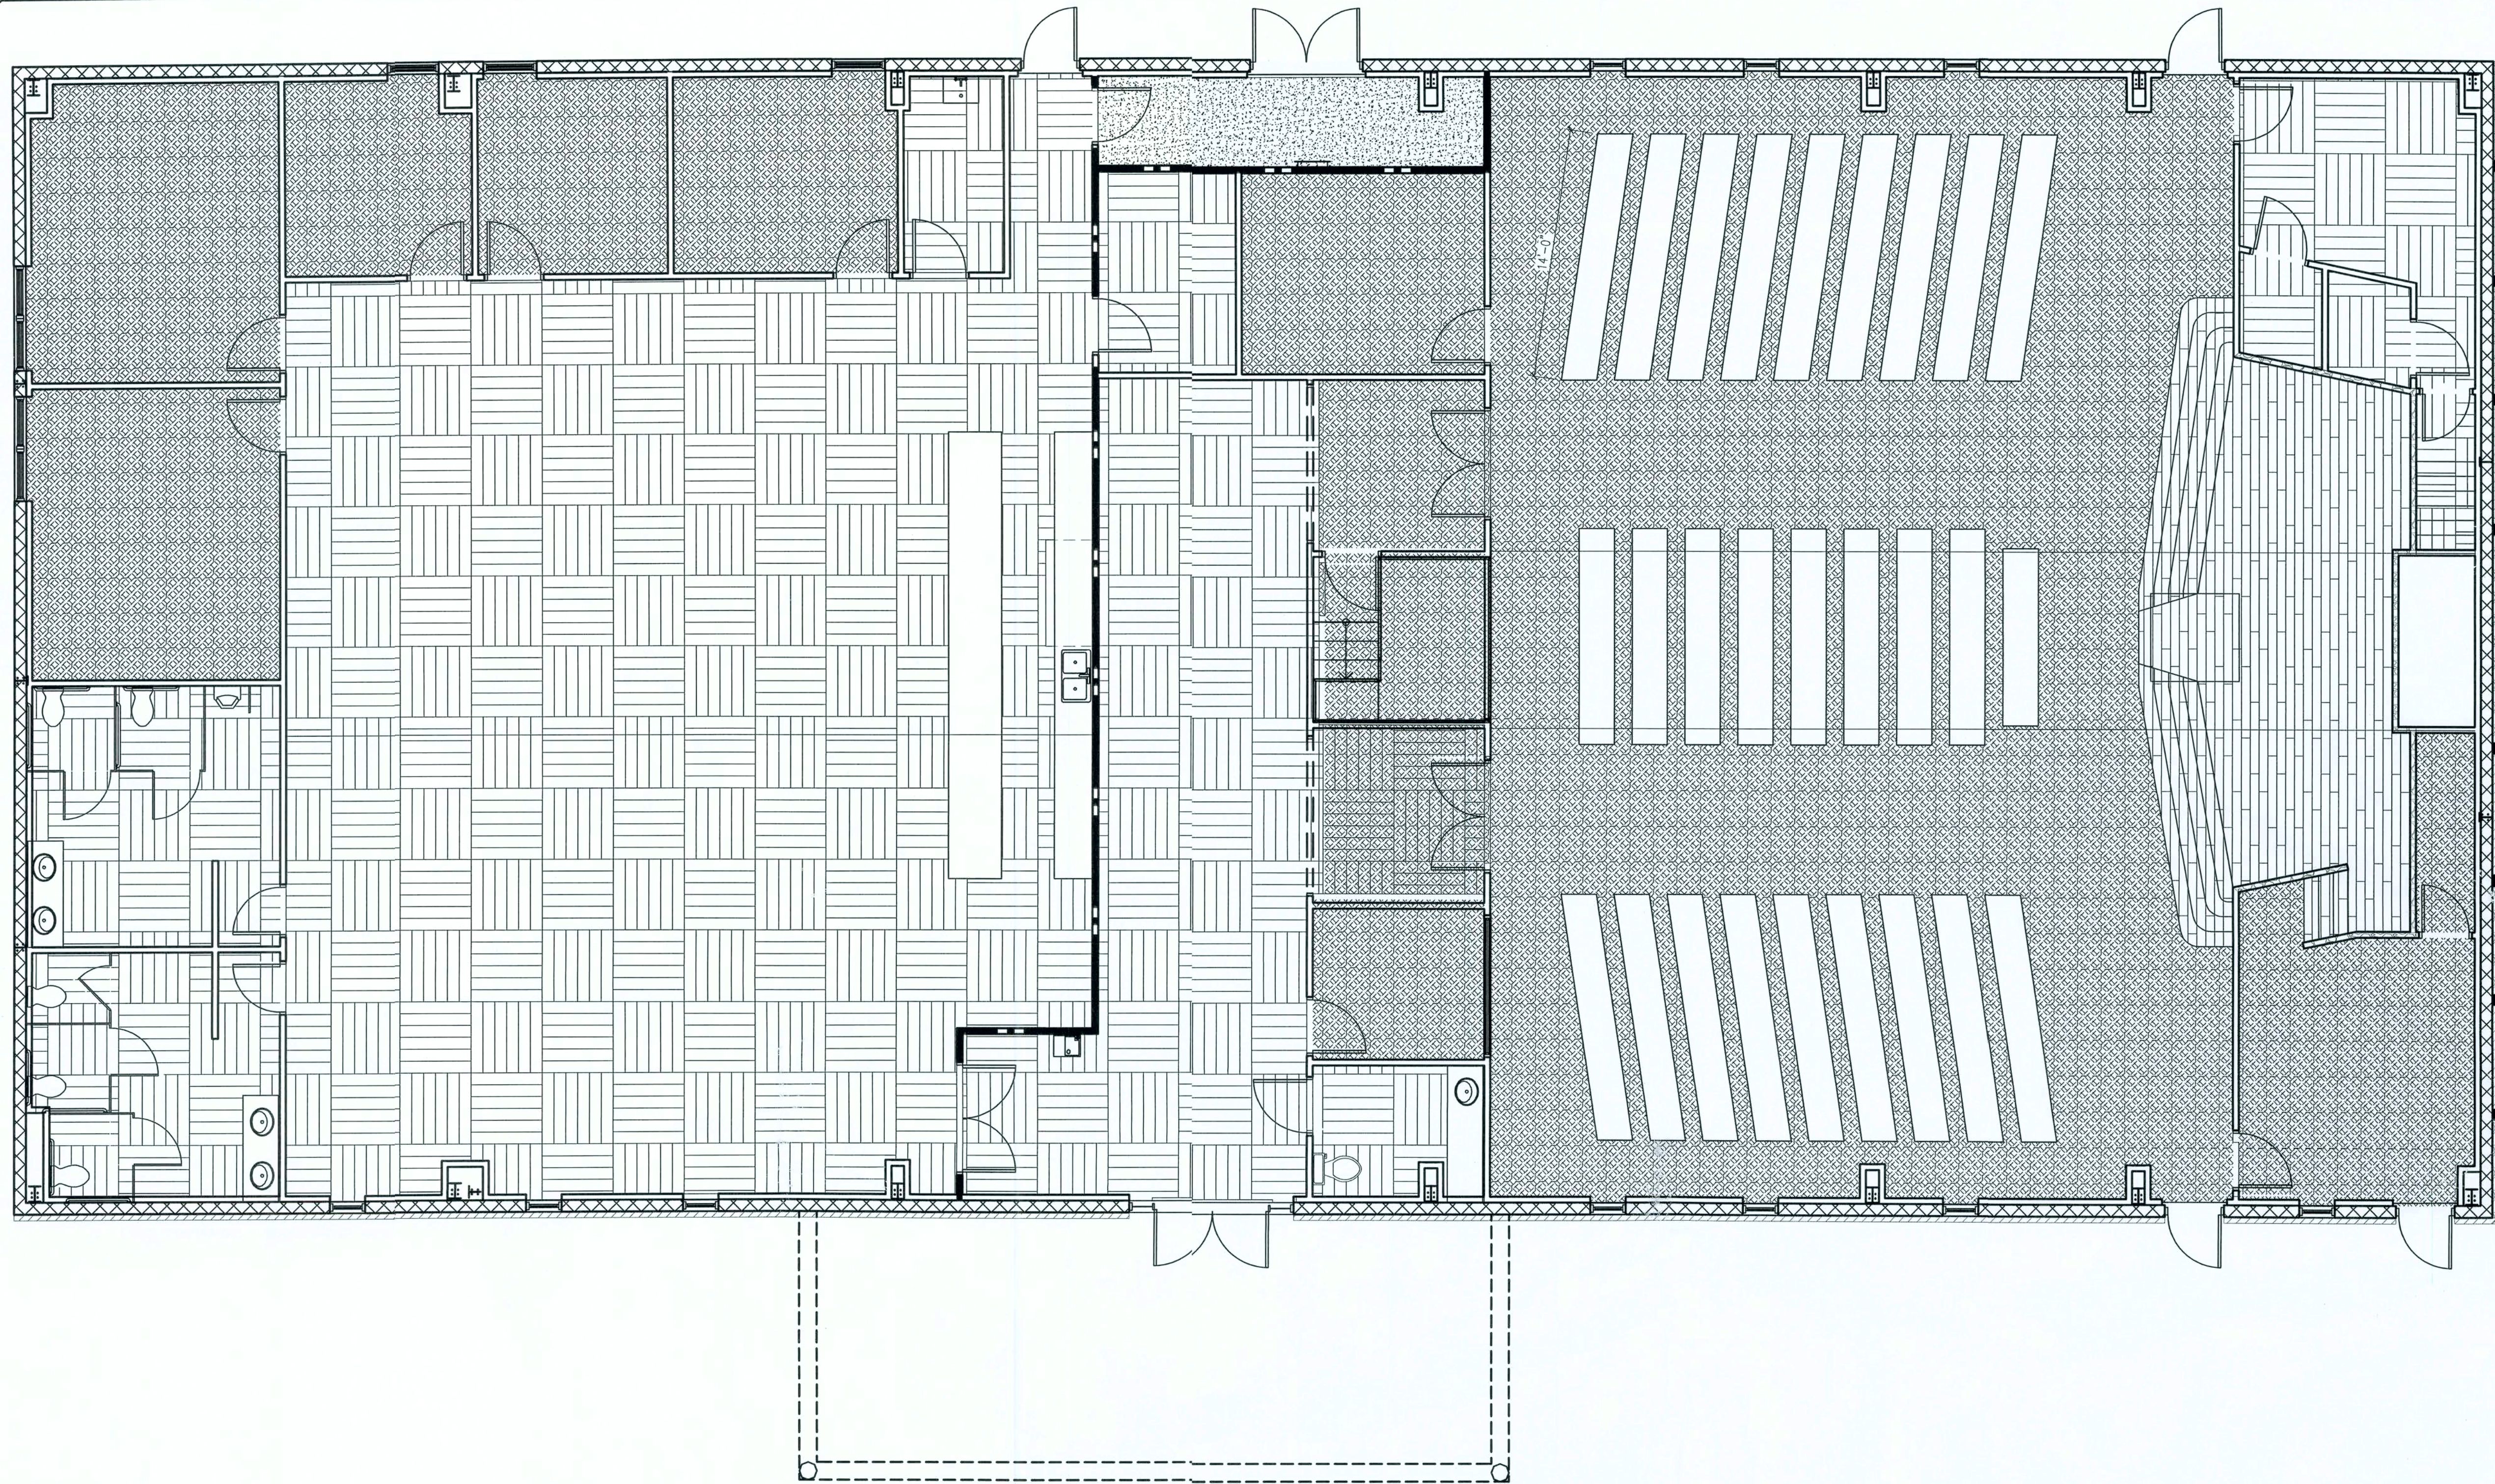

FLOOR FINISH LEGEND	
	COMMERCIAL GRADE CARPET
	WOOD FLOORING
	CERAMIC FLOOR TILE
	CONCRETE FLOOR

DOOR SCHEDULE					
MARK	DOOR SIZE			FIRE RATING LABEL	NOTES
	WD	HGT	THK		
1	6'-4"	6'-10"	1 3/4"	N/A	---
2	3'-0"	6'-8"	1 3/4"	N/A	---
3	3'-0"	6'-8"	1 3/4"	N/A	---
4	3'-0"	6'-8"	1 3/4"	N/A	---
5	6'-0"	6'-8"	1 3/4"	N/A	---
6	3'-0"	6'-8"	1 3/4"	N/A	---
7	3'-0"	6'-8"	1 3/4"	N/A	---
8	3'-0"	6'-8"	1 3/4"	N/A	---
9	3'-0"	6'-8"	1 3/4"	N/A	---
10	2'-8"	6'-8"	1 3/4"	N/A	---
11	2'-8"	6'-8"	1 3/4"	N/A	---
12	3'-0"	6'-8"	1 3/4"	N/A	---
13	6'-0"	6'-8"	1 3/4"	N/A	---
13	3'-0"	6'-8"	1 3/4"	N/A	---
14	3'-0"	6'-8"	1 3/4"	N/A	---
15	9'-0"	8'-0"	NA	N/A	FRAMED ARCH. OPENING
16	3'-0"	6'-8"	1 3/4"	N/A	---
17	9'-0"	8'-0"	NA	N/A	FRAMED ARCH. OPENING
18	6'-0"	6'-8"	1 3/4"	N/A	---
19	3'-0"	6'-8"	1 3/4"	N/A	---
20	3'-0"	6'-8"	1 3/4"	1 HOUR	---
21	3'-0"	6'-8"	1 3/4"	1 HOUR	---
22	3'-0"	6'-8"	1 3/4"	N/A	---
23	3'-0"	6'-8"	1 3/4"	N/A	---
24	3'-0"	6'-8"	1 3/4"	N/A	---
25	3'-0"	6'-8"	1 3/4"	N/A	---
26	3'-0"	6'-8"	1 3/4"	N/A	---
27	3'-0"	6'-8"	1 3/4"	N/A	---
28	3'-0"	6'-8"	1 3/4"	---	---
29	3'-0"	6'-8"	1 3/4"	---	---
30	6'-0"	6'-8"	1 3/4"	1 HOUR	---

ROOM FINISH SCHEDULE										
ROOM NO	ROOM NAME	WALLS			CEILING		NOTES	FLOOR		Base Area
		WALL MATERIAL	WALL FINISH	WALL COLOR	MATL	HEIGHT		Floor Color	Floor Fin	
100	SANCTUARY	5/8" G.W.B.	SEMI GLOSS PAINT	---	ACCOUSTICAL CEILING TILE	10'-0"	---	---	COMMERCIAL GRADE CARPET	2517.87 SF
101	WOMEN'S BATH	5/8" G.W.B.	SEMI GLOSS PAINT	---	ACCOUSTICAL CEILING TILE	10'-0"	---	---	CERAMIC FLOOR TILE	200.67 SF
102	MEN'S BATH	5/8" G.W.B.	SEMI GLOSS PAINT	---	ACCOUSTICAL CEILING TILE	10'-0"	---	---	CERAMIC FLOOR TILE	210.22 SF
103	CLASSROOM 1	5/8" G.W.B.	SEMI GLOSS PAINT	---	ACCOUSTICAL CEILING TILE	10'-0"	---	---	COMMERCIAL GRADE CARPET	238.89 SF
104	CLASSROOM 2	5/8" G.W.B.	SEMI GLOSS PAINT	---	ACCOUSTICAL CEILING TILE	10'-0"	---	---	COMMERCIAL GRADE CARPET	248.44 SF
105	CLASSROOM 3	5/8" G.W.B.	SEMI GLOSS PAINT	---	ACCOUSTICAL CEILING TILE	10'-0"	---	---	COMMERCIAL GRADE CARPET	120.89 SF
106	CLASSROOM 4	5/8" G.W.B.	SEMI GLOSS PAINT	---	ACCOUSTICAL CEILING TILE	10'-0"	---	---	COMMERCIAL GRADE CARPET	120.89 SF
107	CLASSROOM 5	5/8" G.W.B.	SEMI GLOSS PAINT	---	ACCOUSTICAL CEILING TILE	10'-0"	---	---	COMMERCIAL GRADE CARPET	143.56 SF
108	JANITOR'S CLOSET	5/8" G.W.B.	SEMI GLOSS PAINT	---	ACCOUSTICAL CEILING TILE	10'-0"	---	---	CERAMIC FLOOR TILE	64.22 SF
109	CLASSROOM 6	5/8" G.W.B.	SEMI GLOSS PAINT	---	ACCOUSTICAL CEILING TILE	10'-0"	---	---	COMMERCIAL GRADE CARPET	159.44 SF
110	CLASSROOM 7	5/8" G.W.B.	SEMI GLOSS PAINT	---	ACCOUSTICAL CEILING TILE	10'-0"	---	---	COMMERCIAL GRADE CARPET	152.23 SF
111	COMMON AREA	5/8" G.W.B.	SEMI GLOSS PAINT	---	ACCOUSTICAL CEILING TILE	10'-0"	Washable ceiling tiles in common area	---	CERAMIC FLOOR TILE	2355.00 SF
112	ENTRANCE AREA	5/8" G.W.B.	SEMI GLOSS PAINT	---	ACCOUSTICAL CEILING TILE	10'-0"	---	---	CERAMIC FLOOR TILE	803.12 SF
114	SOUND ROOM	5/8" G.W.B.	SEMI GLOSS PAINT	---	ACCOUSTICAL CEILING TILE	10'-0"	---	---	COMMERCIAL GRADE CARPET	82.49 SF
115	UNISEX BATH	5/8" G.W.B.	SEMI GLOSS PAINT	--	ACCOUSTICAL CEILING TILE	10'-0"	Unisex bath to be handicapped accessible	---	CERAMIC FLOOR TILE	87.00 SF
116	MOTHER'S ROOM	5/8" G.W.B.	SEMI GLOSS PAINT	---	ACCOUSTICAL CEILING TILE	10'-0"	---	---	CERAMIC FLOOR TILE	74.11 SF
118	STAGE	5/8" G.W.B.	SEMI GLOSS PAINT	---	ACCOUSTICAL CEILING TILE	10'-0"	---	---	COMMERCIAL GRADE CARPET	328.18 SF
119	CHANGING ROOM 1	5/8" G.W.B.	SEMI GLOSS PAINT	---	ACCOUSTICAL CEILING TILE	10'-0"	---	---	CERAMIC FLOOR TILE	26.41 SF
120	CHANGING ROOM 2	5/8" G.W.B.	SEMI GLOSS PAINT	---	ACCOUSTICAL CEILING TILE	10'-0"	---	---	CERAMIC FLOOR TILE	26.41 SF
121	STAIRWAY	5/8" G.W.B.	SEMI GLOSS PAINT	---	ACCOUSTICAL CEILING TILE	10'-0"	---	---	COMMERCIAL GRADE CARPET	51.94 SF
122	BAPTISTRY	5/8" G.W.B.	SEMI GLOSS PAINT	---	ACCOUSTICAL CEILING TILE	10'-0"	---	---	COMMERCIAL GRADE CARPET	45.11 SF
123	STORAGE 2	5/8" G.W.B.	SEMI GLOSS PAINT	---	ACCOUSTICAL CEILING TILE	10'-0"	---	---	CERAMIC FLOOR TILE	40.94 SF
124	STORAGE 1	5/8" G.W.B.	SEMI GLOSS PAINT	---	ACCOUSTICAL CEILING TILE	10'-0"	---	---	CERAMIC FLOOR TILE	89.44 SF
125	UTILITY ROOM	5/8" G.W.B.	SEMI GLOSS PAINT	---	ACCOUSTICAL CEILING TILE	10'-0"	---	---	CERAMIC FLOOR TILE	115.56 SF
126	PASTOR'S STUDY	5/8" G.W.B.	SEMI GLOSS PAINT	---	ACCOUSTICAL CEILING TILE	10'-0"	---	---	COMMERCIAL GRADE CARPET	223.76 SF

WINDOW SCHEDULE					
MARK	SIZE		TYPE	MATERIAL	NOTES
	WIDTH	HEIGHT			
1	2'-0"	7'-0"	---	---	---
2	2'-0"	7'-0"	---	---	---
3	2'-0"	7'-0"	---	---	---
4	2'-0"	7'-0"	---	---	---
5	2'-0"	7'-0"	---	---	---
6	2'-0"	7'-0"	---	---	---
7	2'-0"	7'-0"	---	---	---
8	3'-0"	6'-0"	---	---	---
9	3'-0"	6'-0"	---	---	---
10	3'-0"	6'-0"	---	---	DOUBLE PANE
11	3'-0"	6'-0"	---	---	DOUBLE PANE
12	3'-0"	6'-0"	---	---	DOUBLE PANE
13	3'-0"	6'-0"	---	---	DOUBLE PANE
14	3'-0"	6'-0"	---	---	DOUBLE PANE
15	2'-0"	7'-0"	---	---	DOUBLE PANE
16	2'-0"	7'-0"	---	---	DOUBLE PANE
17	2'-0"	7'-0"	---	---	DOUBLE PANE
18	8'-0"	4'-0"	---	---	ONE-WAY GLASS

REVISION NOTES

REV #	DATE	###

P.O. Box 187
130 West Howard Street
Live Oak, FL 32064
Phone: (386) 362-3678
Fax: (386) 362-6133


STRUCTURAL CIVIL ENGINEERS
Gary Gill, PE 51942
Autl. # 9461

7TH DAY ADVENTIST CHURCH
NEW WORSHIP CENTER
COLUMBIA COUNTY, FLORIDA

FINISH PLAN

PROJECT NUMBER
PF08-193S

DRAWN BY
-

CHECKED BY
G.G.

A-1.2

SHEET 3 OF 16

ISSUED FOR APPROVAL


9/5/07

SHEET KEYNOTES

- 1 STONE VENEER (PER OWNER)
- 2 29ga. METAL SIDING (PER OWNER)
- 3 29ga. METAL ROOFING (PER OWNER)
- 4 8 x 8 x 8 CMU BLOCK COLUMN W/ DECORATIVE SHEATHING (PER OWNER)
- 5 DECORATIVE BRICK VENEER

NOTE:

1.) STEEPLE BY OTHERS

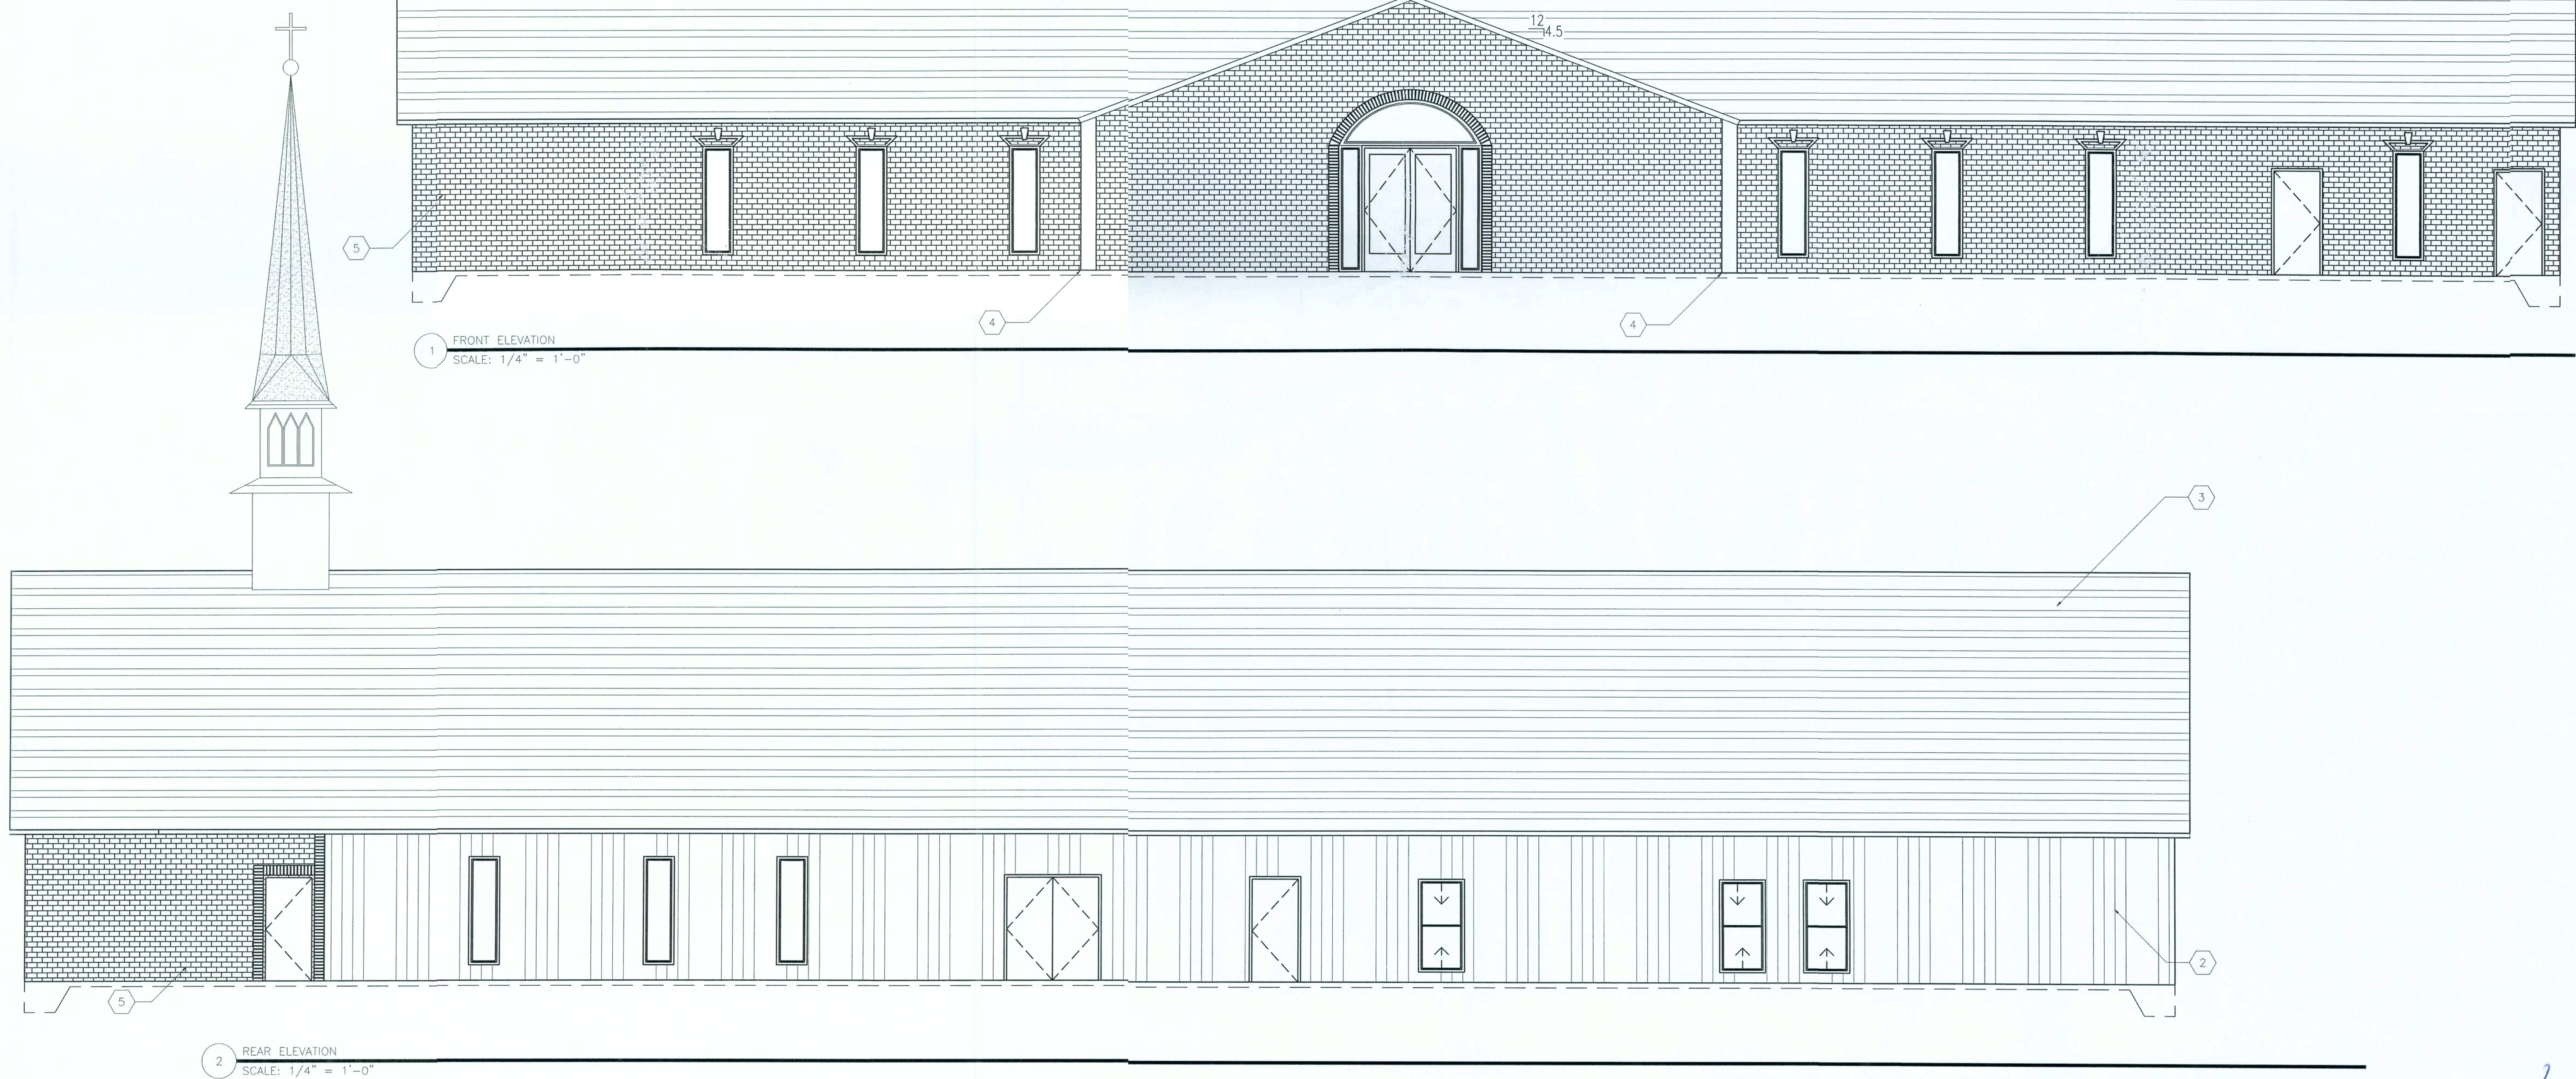

ISSUED FOR APPROVAL

L
7/5/07

REV #	DATE	REVISION NOTES
-	10-20-06	ISSUED FOR CONSTRUCTION

P.O. Box 187
130 West Howard Street
Live Oak FL 32064
Phone: (386) 362-3678
Fax: (386) 362-6133
Auth. # 9461

JG
STRUCTURAL CIVIL ENGINEERS

7th ADVENTIST CHURCH
NEW WORSHIP CENTER
COLUMBIA COUNTY, FLORIDA



ELEVATIONS
PROJECT NUMBER PF06-193S
DRAWN BY D. PRICE
CHECKED BY G.G.
A-2.0
SHEET 4 OF 16

SHEET KEYNOTES

- 1 STONE VENEER (PER OWNER)
- 2 29ga. METAL SIDING (PER OWNER)
- 3 29ga. METAL ROOFING (PER OWNER)
- 4 12" # COLUMN (PER OWNER)
- 5 DECORATIVE BRICK VENEER


NOTE:

1.) STEEPLE BY OTHERS

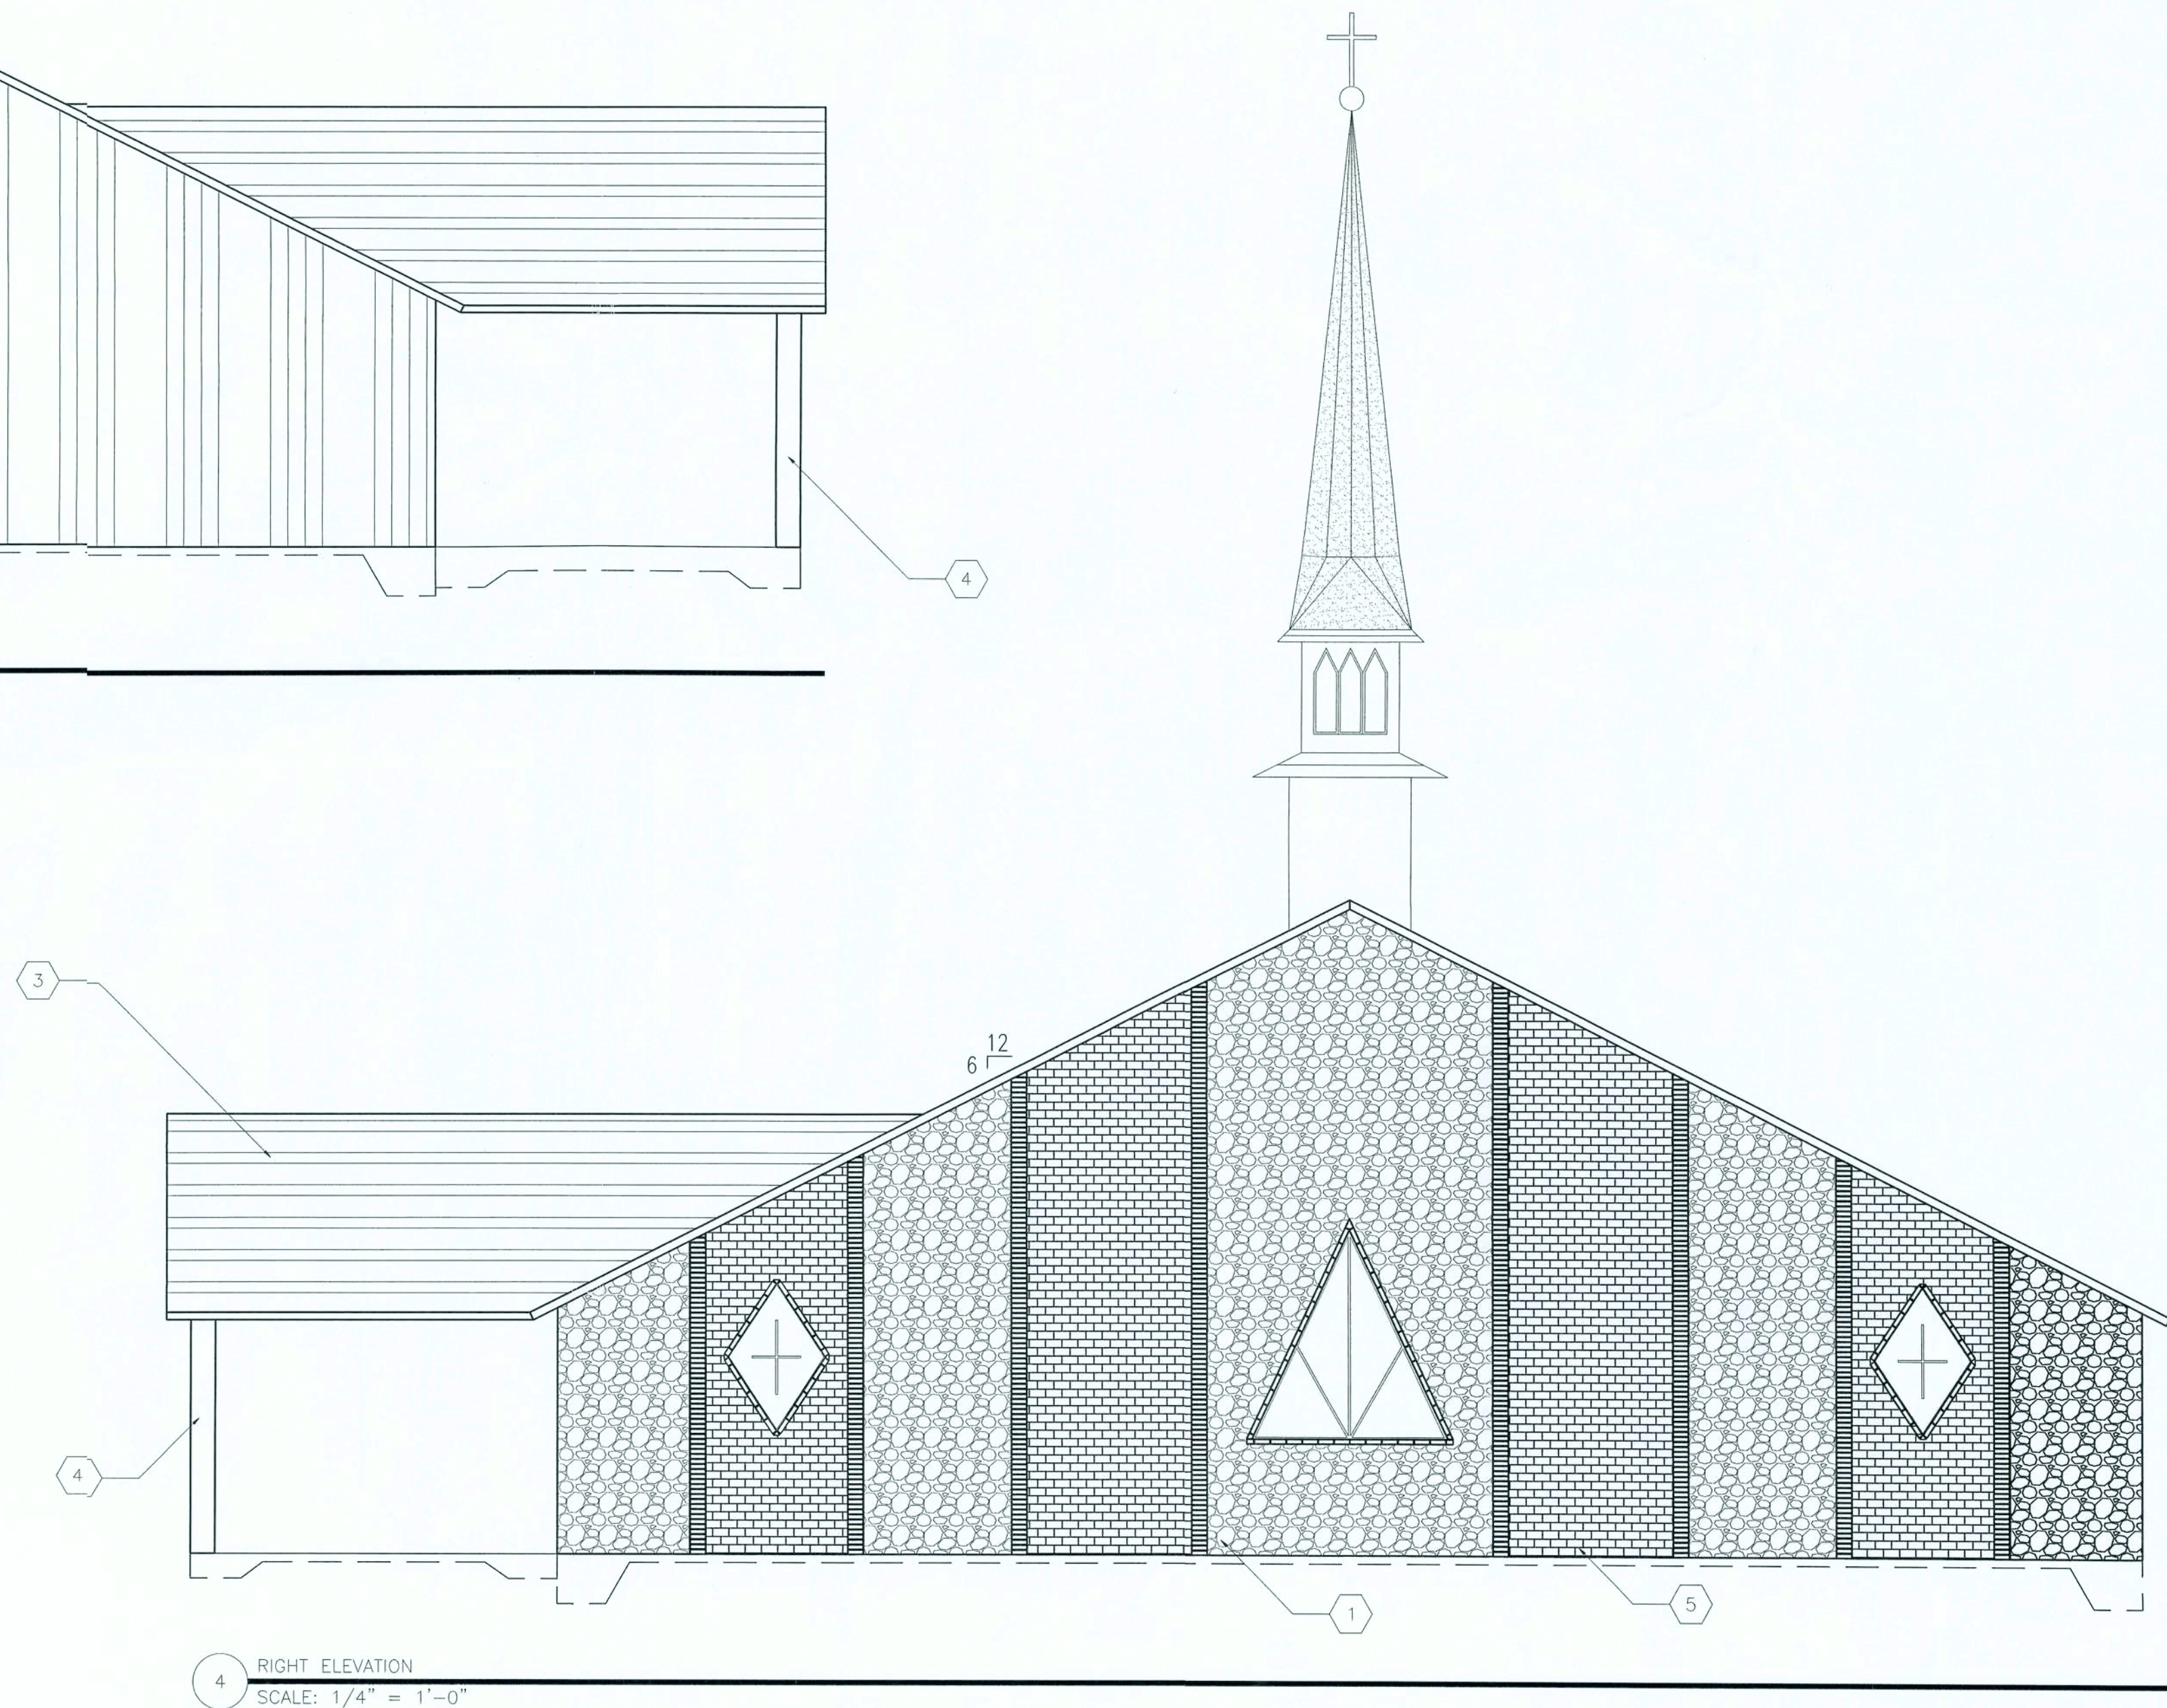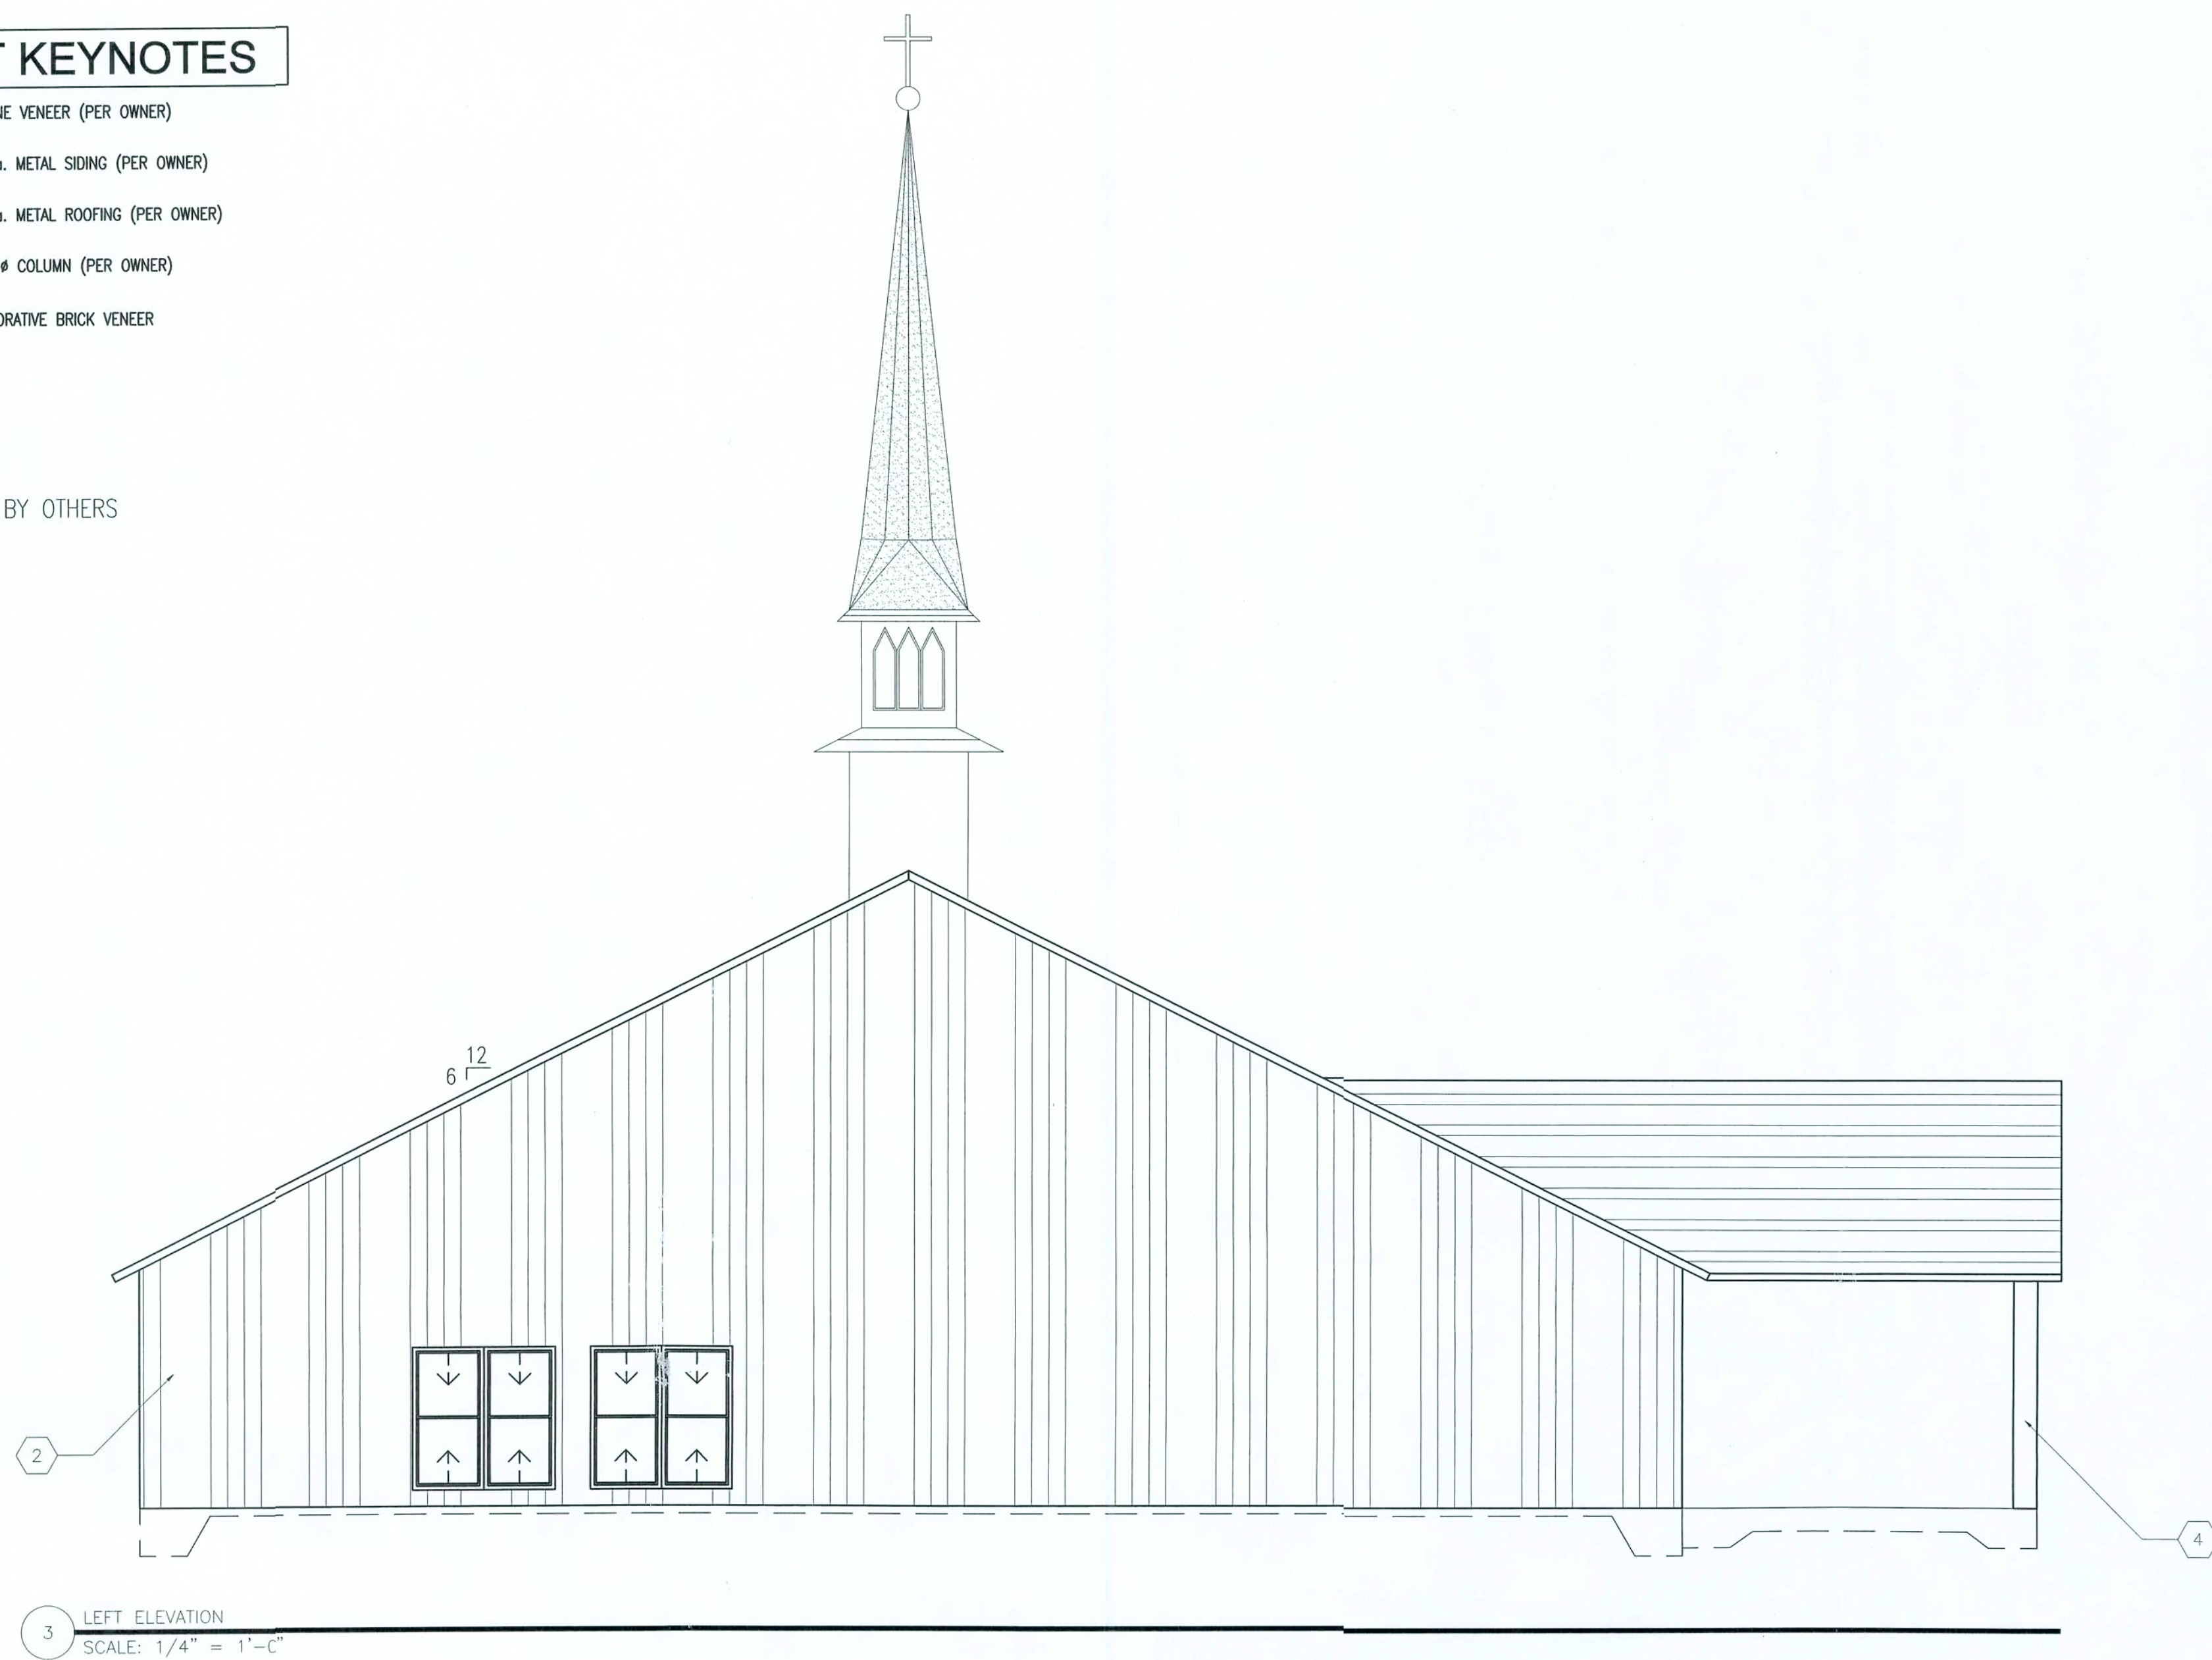

ISSUED FOR APPROVAL

REVISION NOTES		DATE	REV #
ISSUED FOR	CONSTRUCTION		
		10-20-06	-
P.O. Box 187 130 West Howard Street Live Oak FL 32064 Phone: (386) 362-3678 Fax: (386) 362-6133 GARY GILL, P.E. 51942 Auditor # 9461			
			
7th ADVENTIST CHURCH NEW WORSHIP CENTER COLUMBIA COUNTY, FLORIDA			
ELEVATIONS			
PROJECT NUMBER PF06-193S			
DRAWN BY ####			
CHECKED BY G.G.			
A-2.1			
SHEET 5 OF 16			

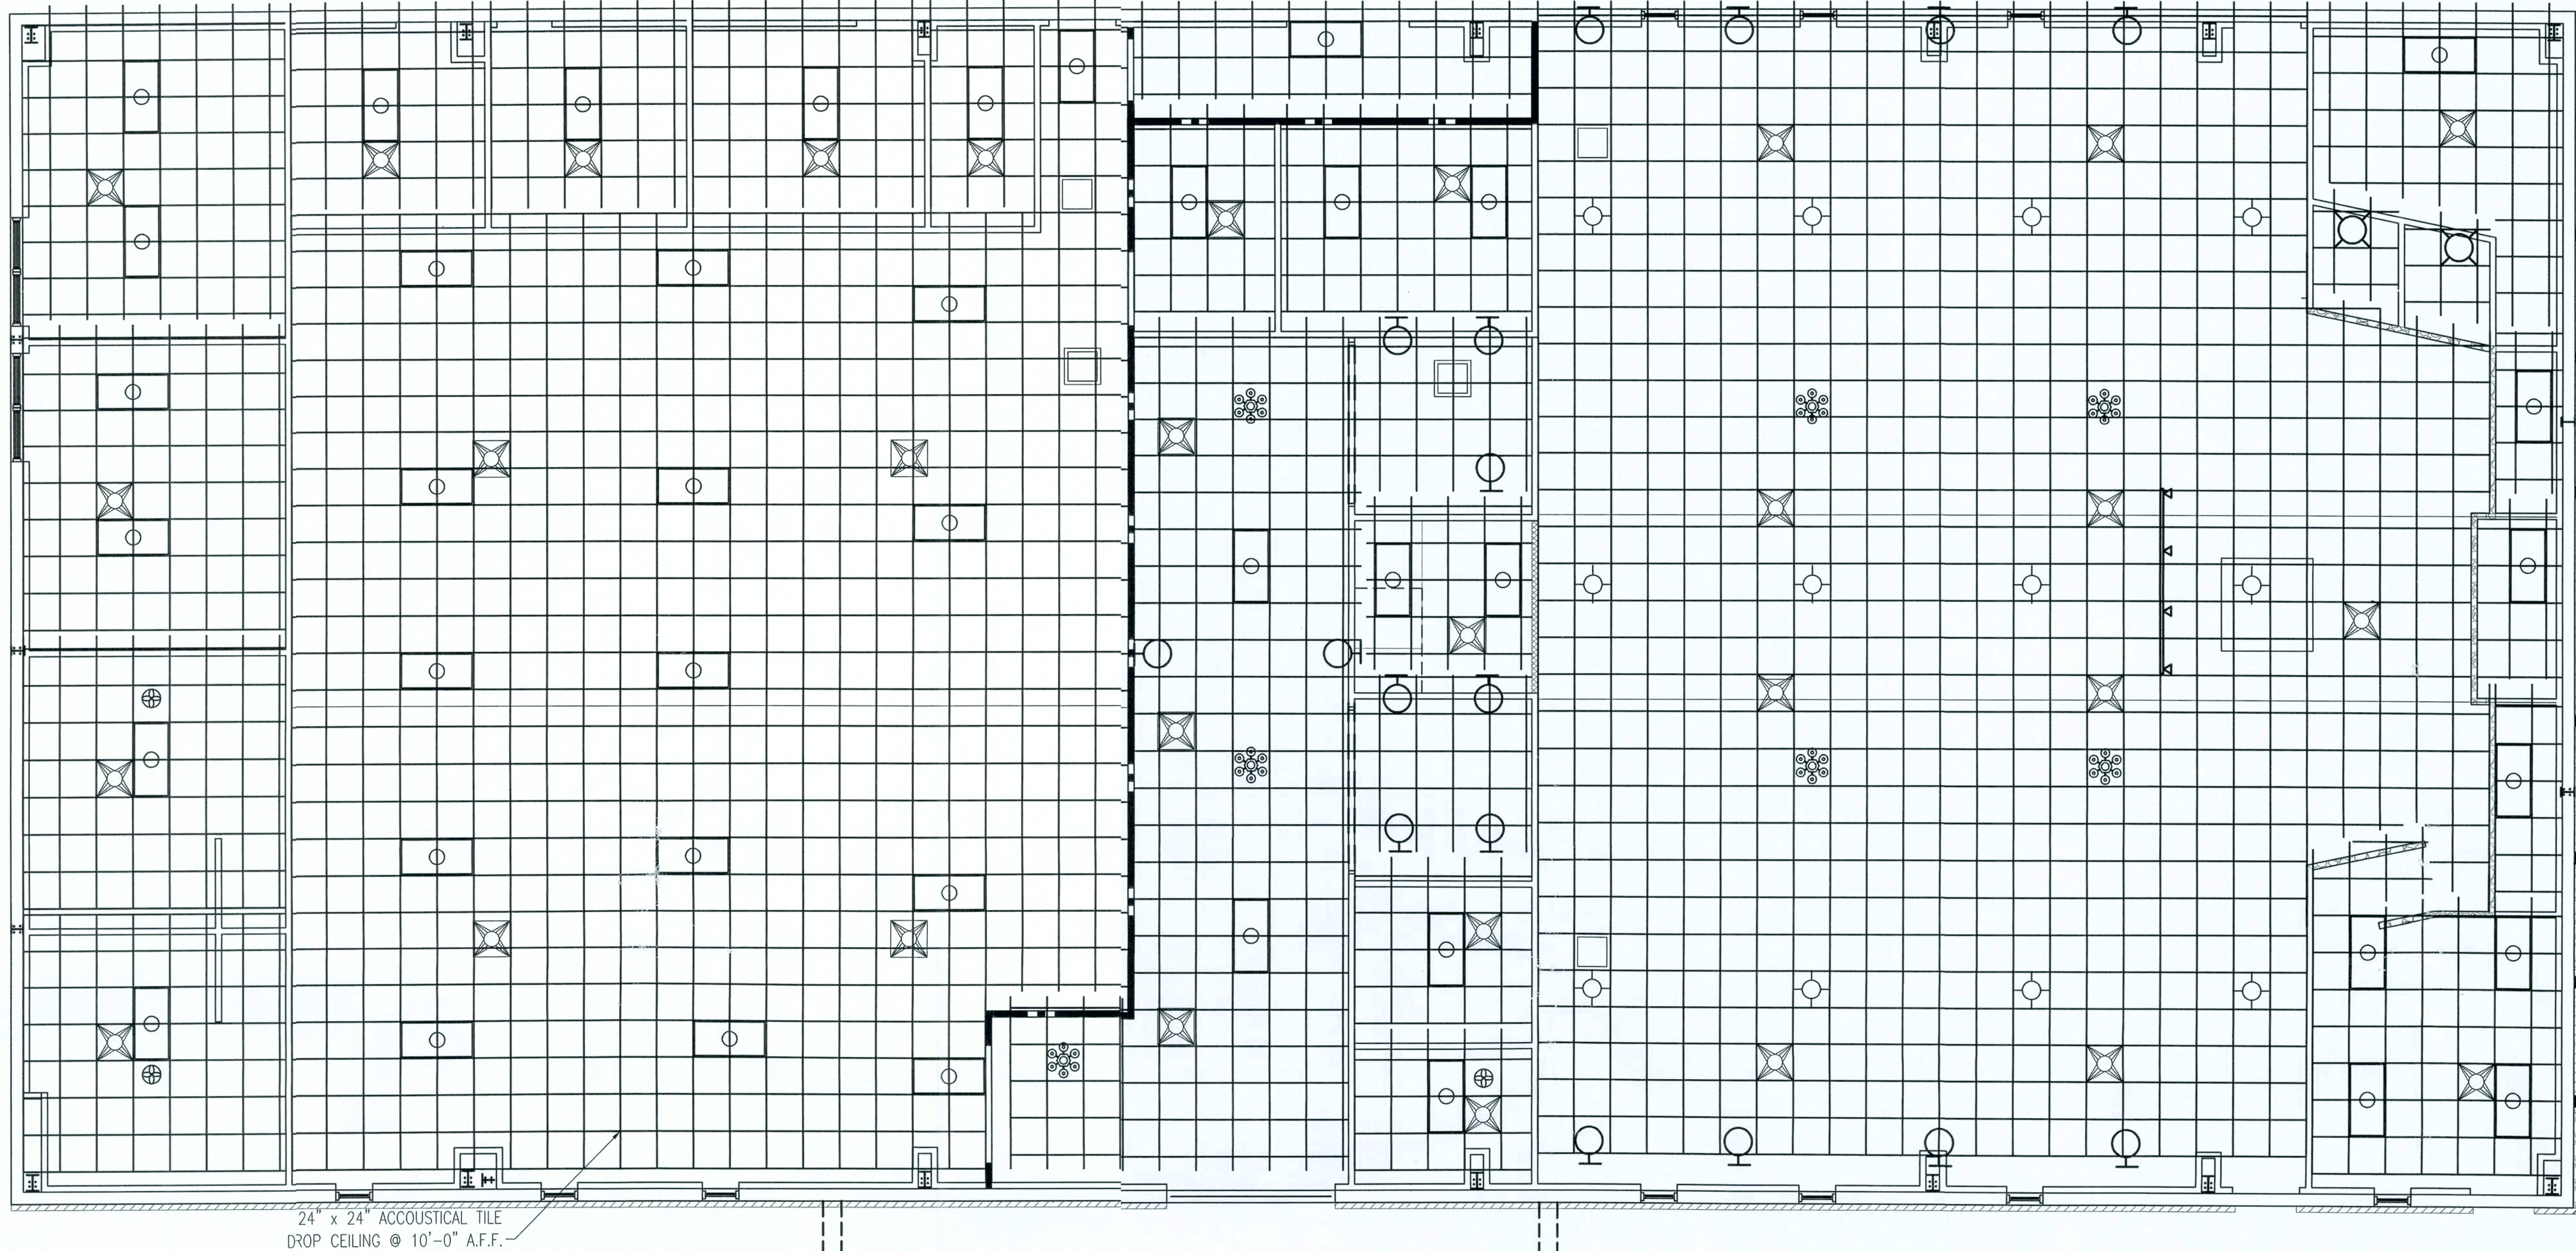

24" x 24" ACOUSTICAL TILE
DROP CEILING @ 10'-0" A.F.F.

REFLECTED CEILING PLAN
SCALE: 3/16" = 1'-0"

LEGEND	
SYMBOL	DESCRIPTION
	SPOT LIGHT
	EXHAUST FAN
	DECORATIVE HANGING CHANDELIER
	24 x 48 FLUORESCENT LIGHT
	24 x 24 AIR RETURN
	24 x 24 AIR VENT
	48\"/>

NOTES:

- 1.) CEILING TILES IN COMMON AREA TO BE OF WASHABLE TYPE.
- 2.) LEGEND QUANTITIES ARE FOR CEILING MOUNTED OBJECTS ONLY. QUANTITIES MAY BE DIFFERENT ON OTHER ELECTRICAL SHEETS.

ISSUED FOR APPROVAL


L
7/15/07

7th ADVENTIST CHURCH
NEW WORSHIP CENTER
COLUMBIA COUNTY, FLORIDA

REFLECTED CEILING PLAN

PROJECT NUMBER
PF06-193S
DRAWN BY
D. PRICE
CHECKED BY
G.G.
A-3.0

REVISION NOTES
ISSUED FOR
CONSTRUCTION
REV # DATE
10-20-06
P.O. Box 187
130 West Howard Street
Live Oak FL 32064
Phone: (386) 362-3678
Fax: (386) 362-6133
Auth. # 9461
STRUCTURAL/CIVIL ENGINEERS Gary Gill, PE 51942

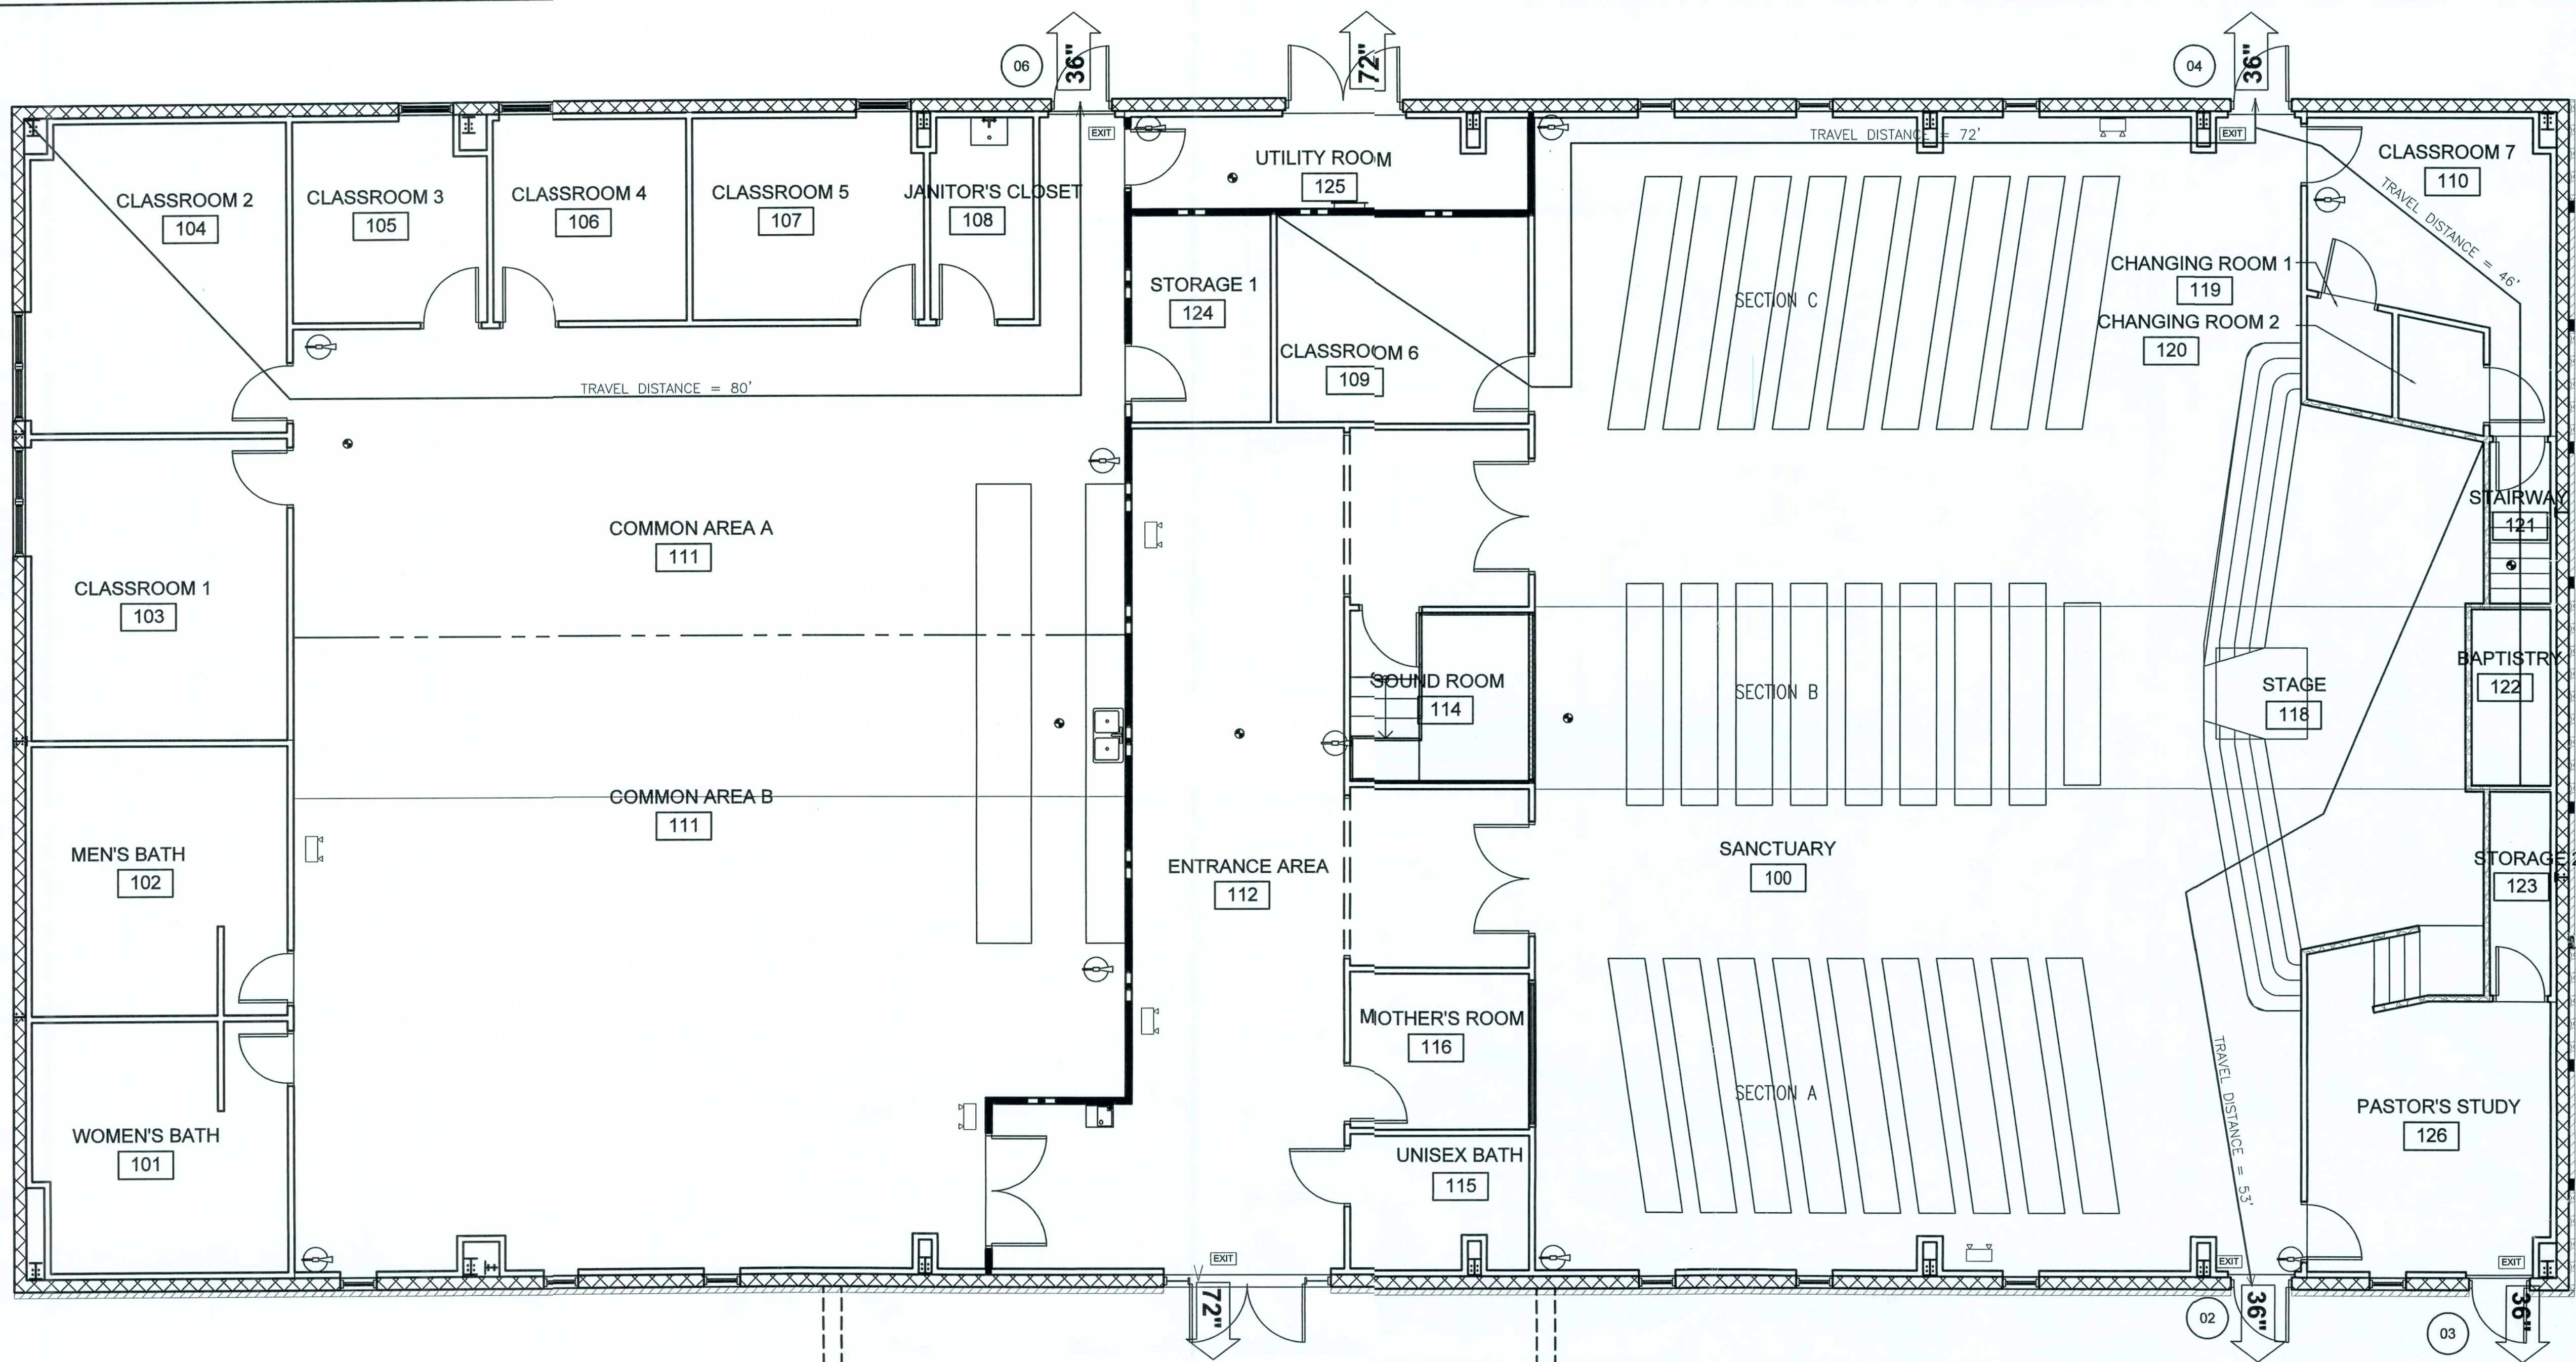

OCCUPANCY SCHEDULE			
ROOM #	DESCRIPTION	MAXIMUM OCCUPANCY	EMERGENCY EXIT DOOR
100	SANCTUARY	179	A&B - 2 C - 4
109	CLASSROOM 6	10	4
114	SOUND ROOM	5	1
116	MOTHER'S ROOM	5	1
118	STAGE	21	3
110, 119, 120, & 121	CLASSROOM 7, CHANGING ROOMS & STAIRWAY COMBINED	17	4
122	BAPTISTRY	3	4
123	STORAGE 2	1	3
124	STORAGE 1	1	6
125	UTILITY ROOM	1	6
126	PASTOR'S STUDY	14	3
TOTAL MAXIMUM OCCUPANCY OF BUILDING ON THE SANCTUARY SIDE OF THE FIREWALL		257	
103	CLASSROOM 1	15	6
104	CLASSROOM 2	16	6
105	CLASSROOM 3	8	6
106	CLASSROOM 4	8	6
107	CLASSROOM 5	9	6
108	JANITORS CLOSET	1	6
111	COMMON AREA	336	A - 6 B - 1
TOTAL MAXIMUM OCCUPANCY OF BUILDING ON THE COMMON AREA SIDE OF THE FIREWALL		408	
TOTAL BUILDING MAXIMUM OCCUPANCY		655	

LIFE SAFETY PLAN
SCALE: $\frac{3}{16}" = 1'-0"$

MAX OCCUPANCY LOAD
518 PERSONS

SCHEDULE			
SYMBOL	NAME	REMARK	QUANTITY
	EXIT SIGN	LED	6
	EMERGENCY LIGHTS	-	7
	FIRE EXTINGUISHER	ABC TYPE	10
	SMOKE DETECTOR	AC/BATT	8

36" 36" / 0.2" PER OCCUPANT = 180 OCCUPANTS

72" 72" / 0.2" PER OCCUPANT = 360 OCCUPANTS

ISSUED FOR APPROVAL

REV #	DATE	###	REVISION NOTES

P.O. Box 187
130 West Howard Street
Live Oak, FL 32064
Phone: (386) 362-3678
Fax: (386) 362-6133
Gary Gill, PE 51942
Autl. # 9461

STRUCTURAL CIVIL ENGINEERS

7TH DAY ADVENTIST CHURCH
NEW WORSHIP CENTER
COLUMBIA COUNTY, FLORIDA

LIFE SAFETY


PROJECT NUMBER
PF06-193S

DRAWN BY
-

CHECKED BY
G.G.

A-4.0

SHEET 7 OF 16






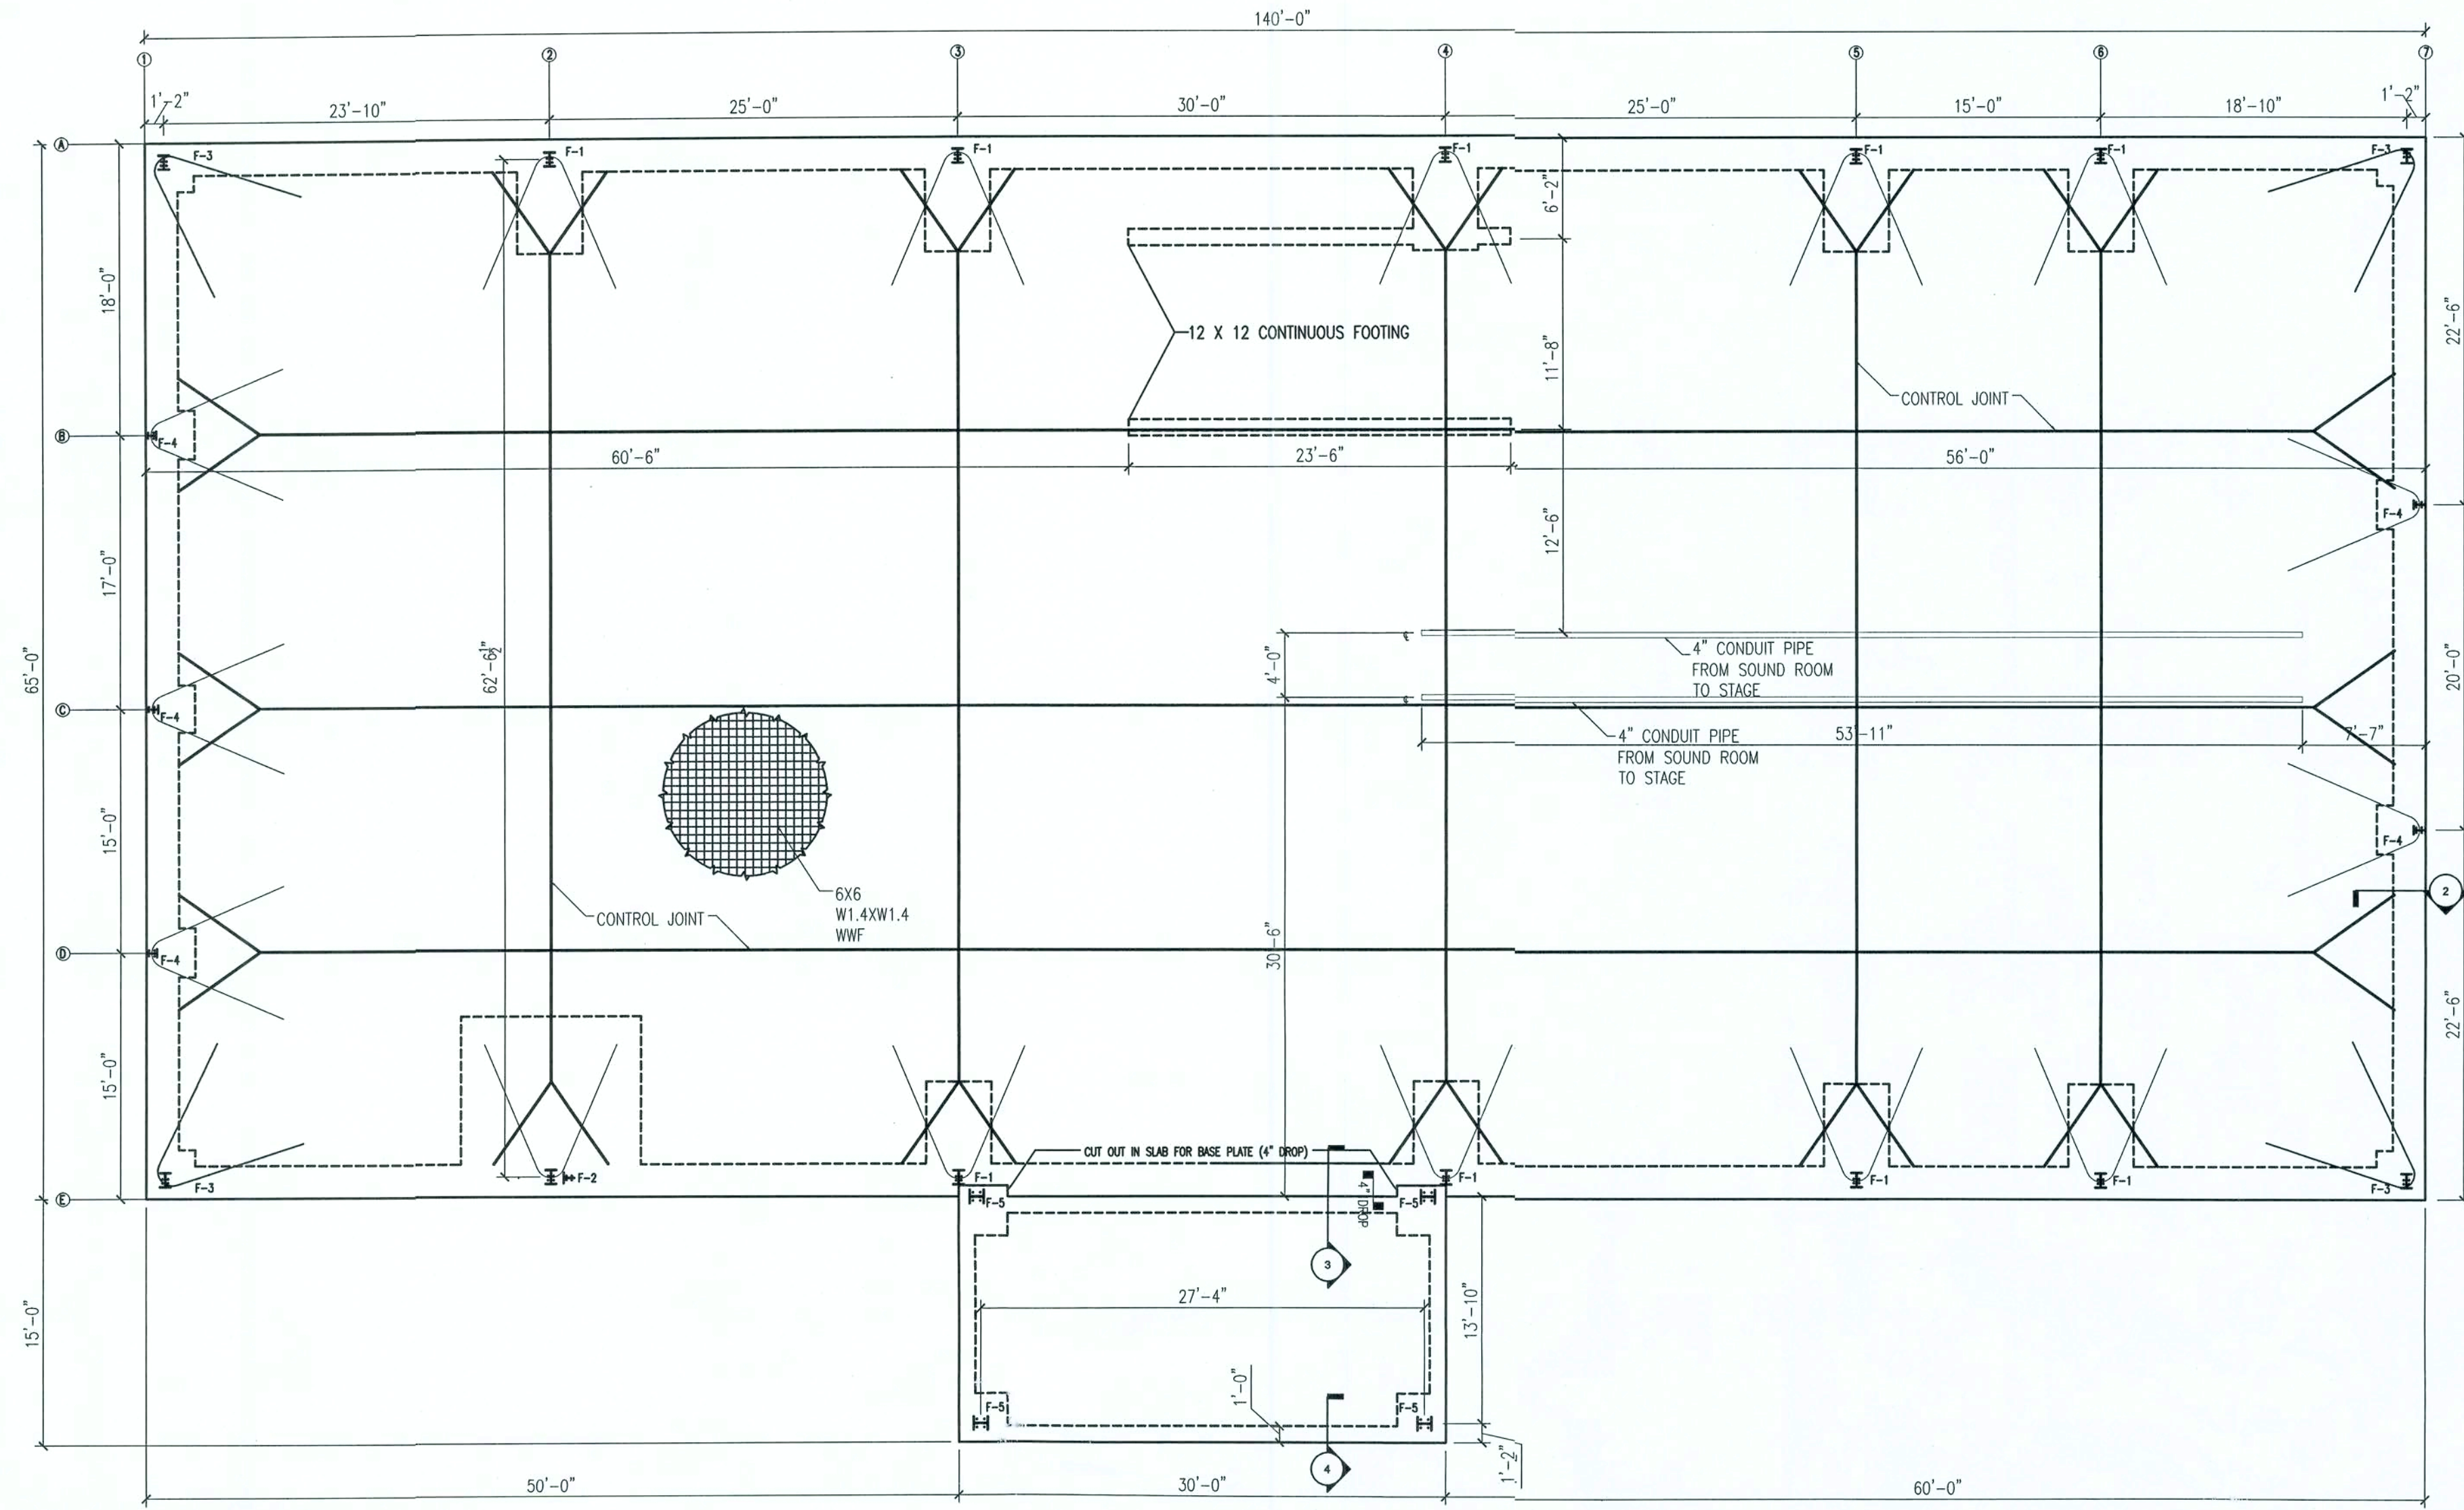


NOTES:



1. ALL MATERIALS USED TO PRODUCE CONCRETE AND ADMIXTURES FOR CONCRETE SHALL COMPLY WITH ACI 318.
2. CONCRETE AGGREGATES SHALL CONFORM TO ACTM C150.
3. CONCRETE SHALL HAVE A SPECIFIED COMPRESSIVE STRENGTH OF NOT LESS THAN 3000 PSI.

FOUNDATION PLAN


SCALE: $\frac{1}{8}'' = 1'-0''$

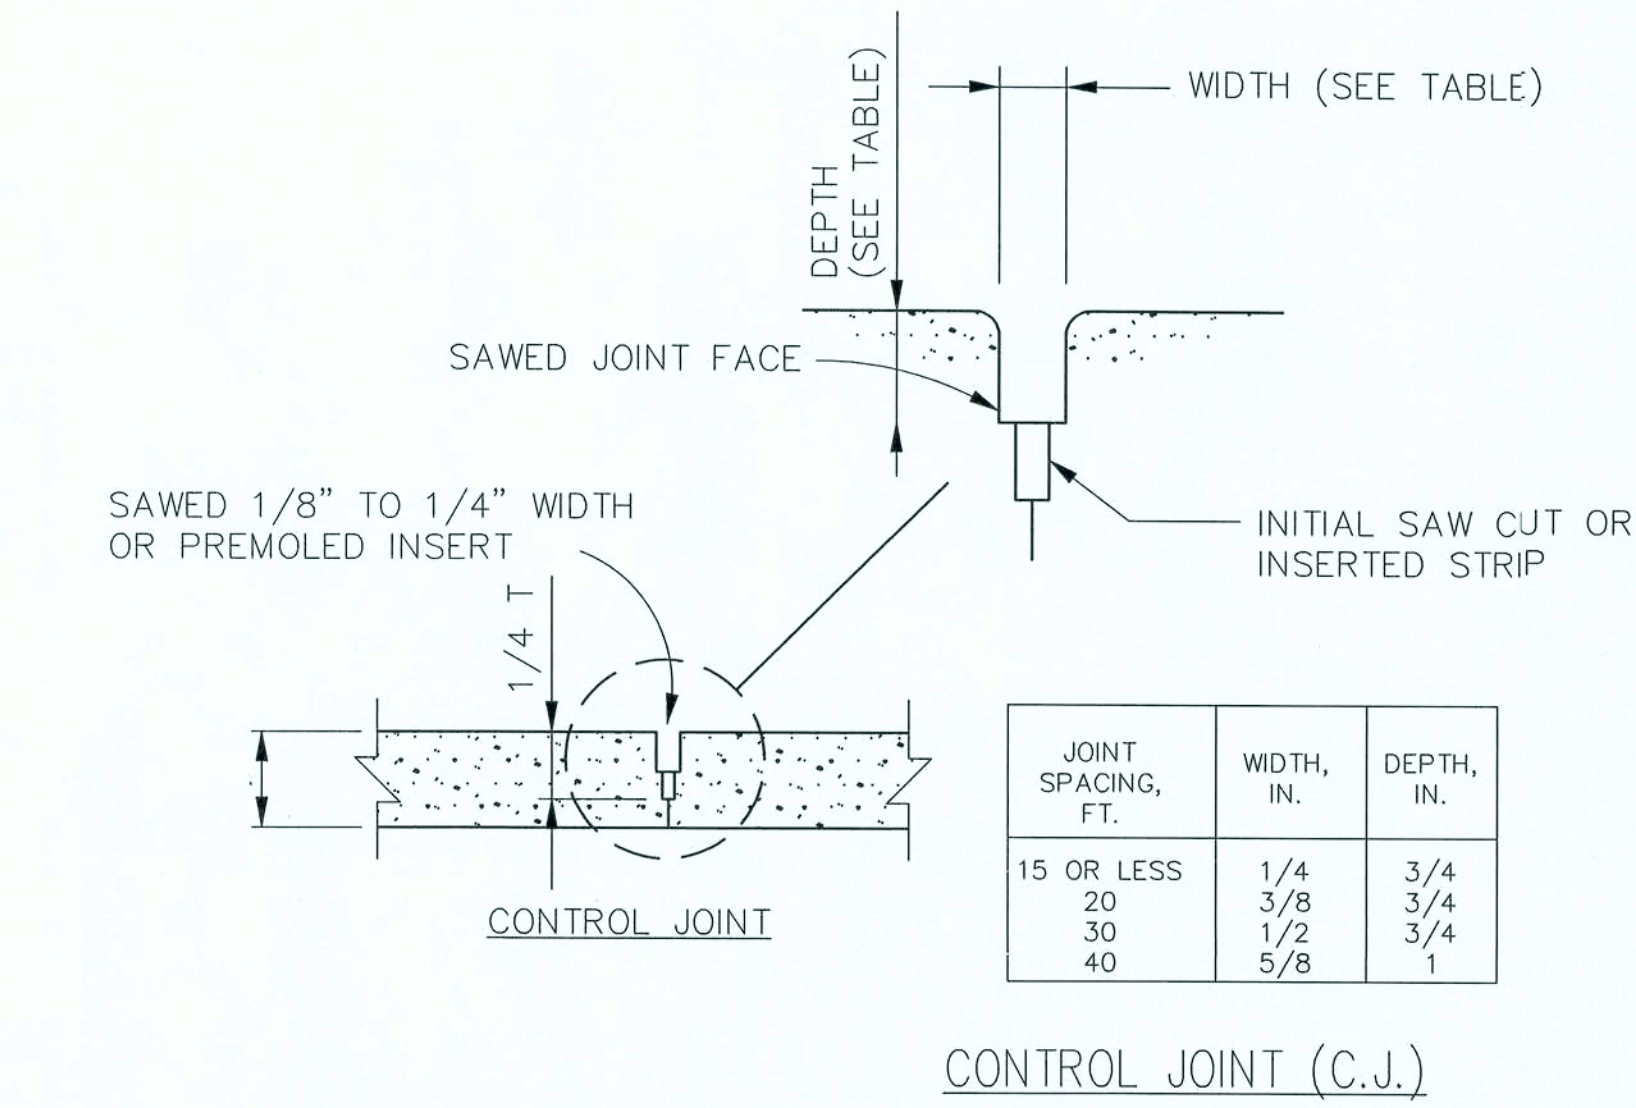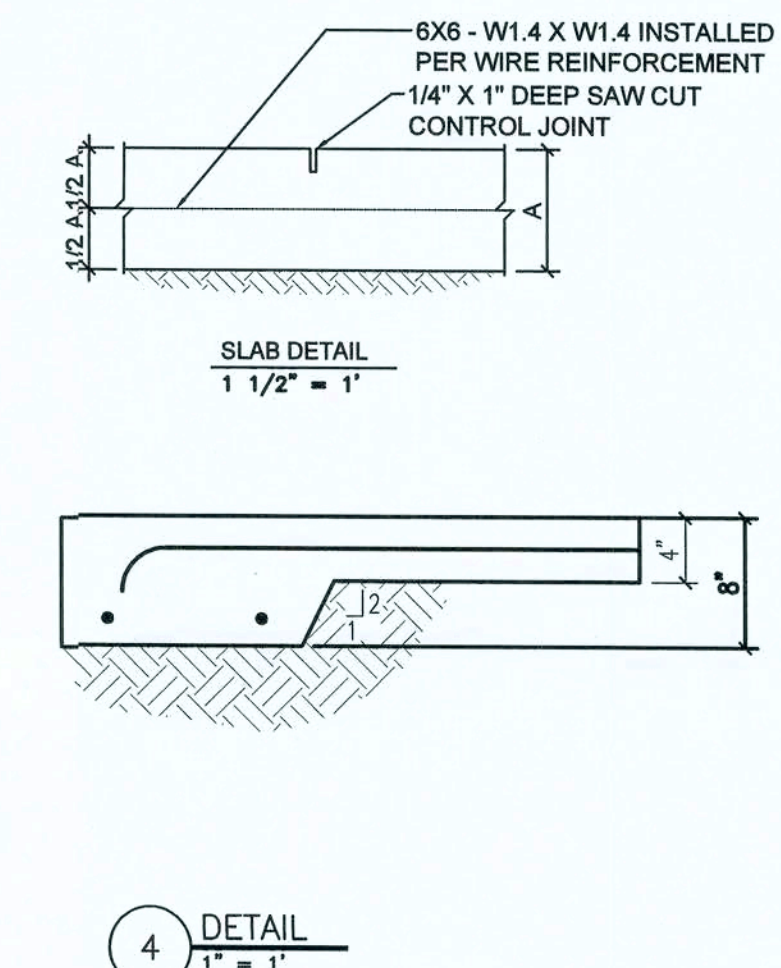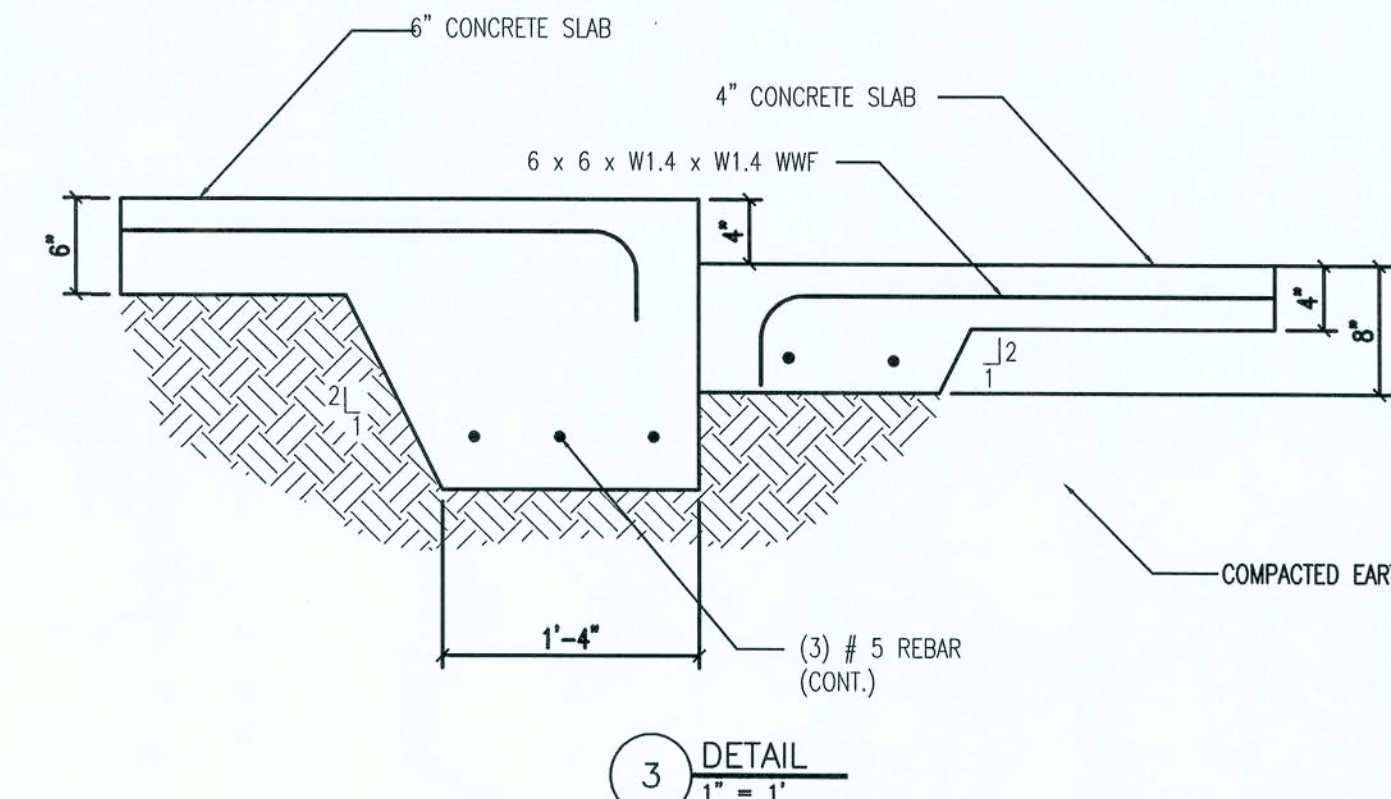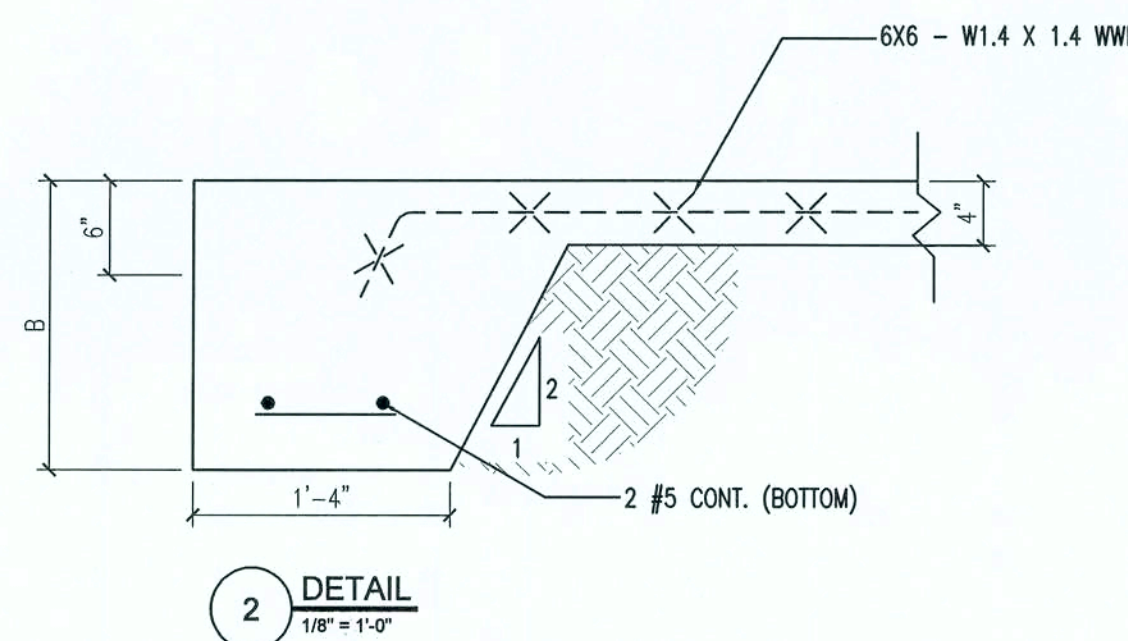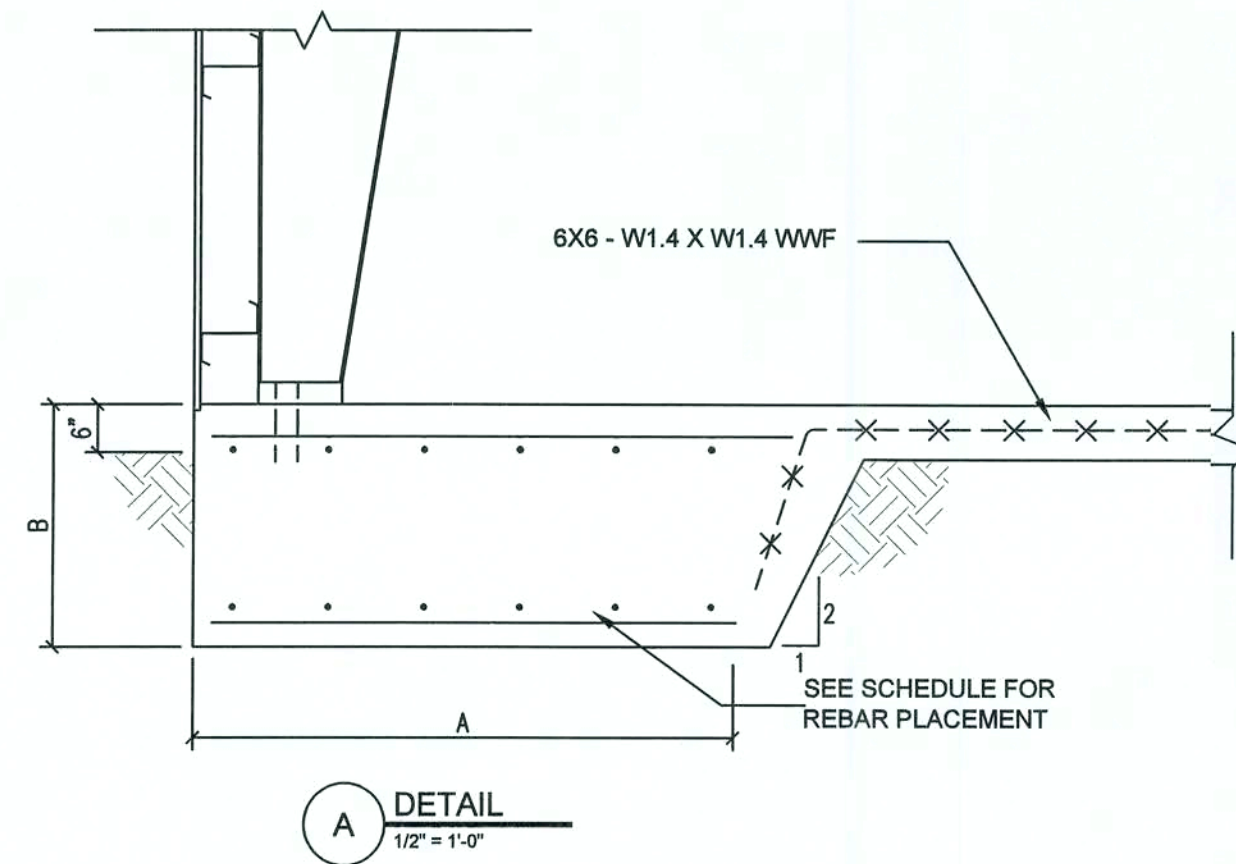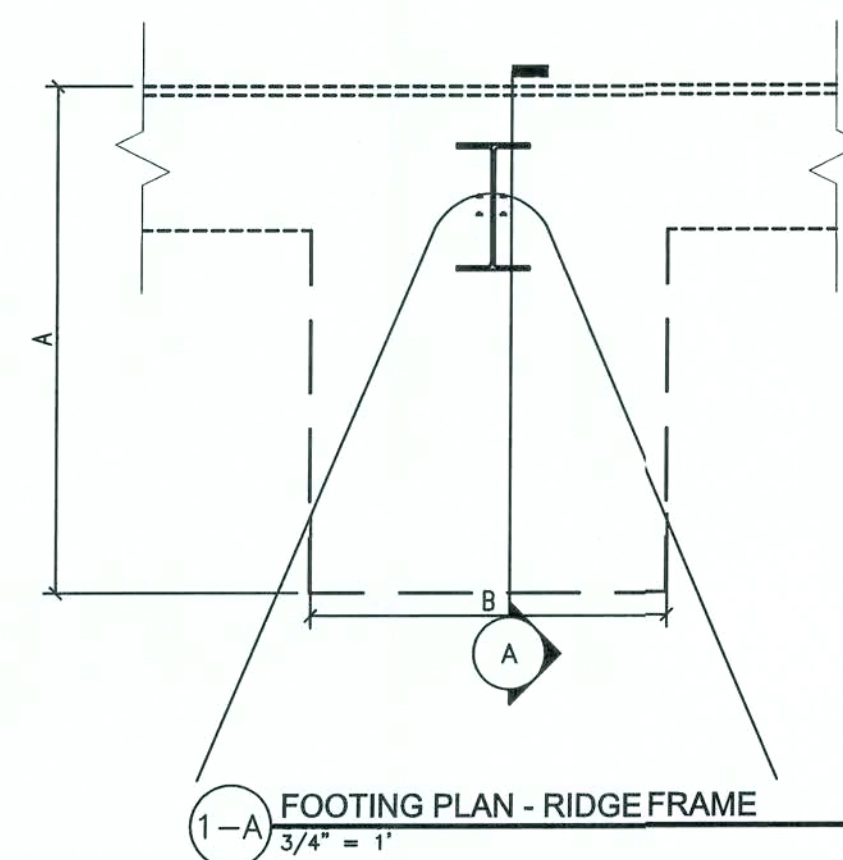


FOOTING SCHEDULE										
FOOTING MARK	FOOTING DIMENSIONS			DETAIL MARK	SECTION MARK	BOTTOM REBAR	TOP REBAR	ANCHOR BOLT		
	A	B	C					DIAMETER	TOTAL LENGTH	EMBEDMENT
F-1	7'-0"	4'-0"	2'-6"	A	1-A	(5) #5 E.W.	(5) #5 E.W.	0'-0 3/4"	1'-6"	1'-0"
F-2	11'-0"	11'-0"	2'-6"	A	1-A	#5 @ 12" O/C.	#5 @ 12" O/C.	0'-1"	1'-6"	1'-6"
F-3	3'-0"	3'-0"	2'-6"	B	1-B	(5) #5 E.W.	(5) #5 E.W.	0'-0 3/4"	1'-6"	1'-0"
F-4	3'-0"	3'-0"	2'-6"	B	1-B	(3) #5 E.W.	(3) #5 E.W.	0'-0 5/8"	1'-6"	1'-0"
F-5	3'-0"	3'-0"	2'-6"	B	1-B	(3) #5 E.W.	(3) #5 E.W.	0'-0 3/4"	1'-6"	1'-0"

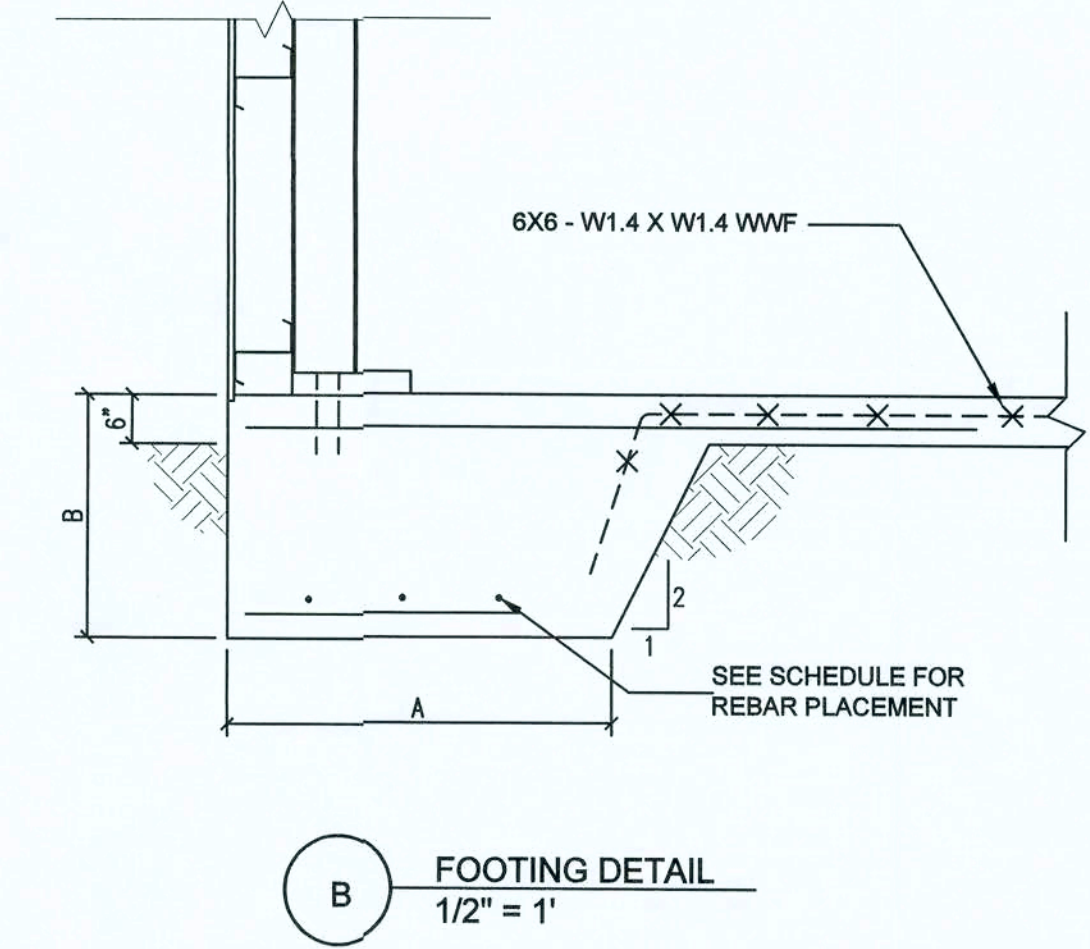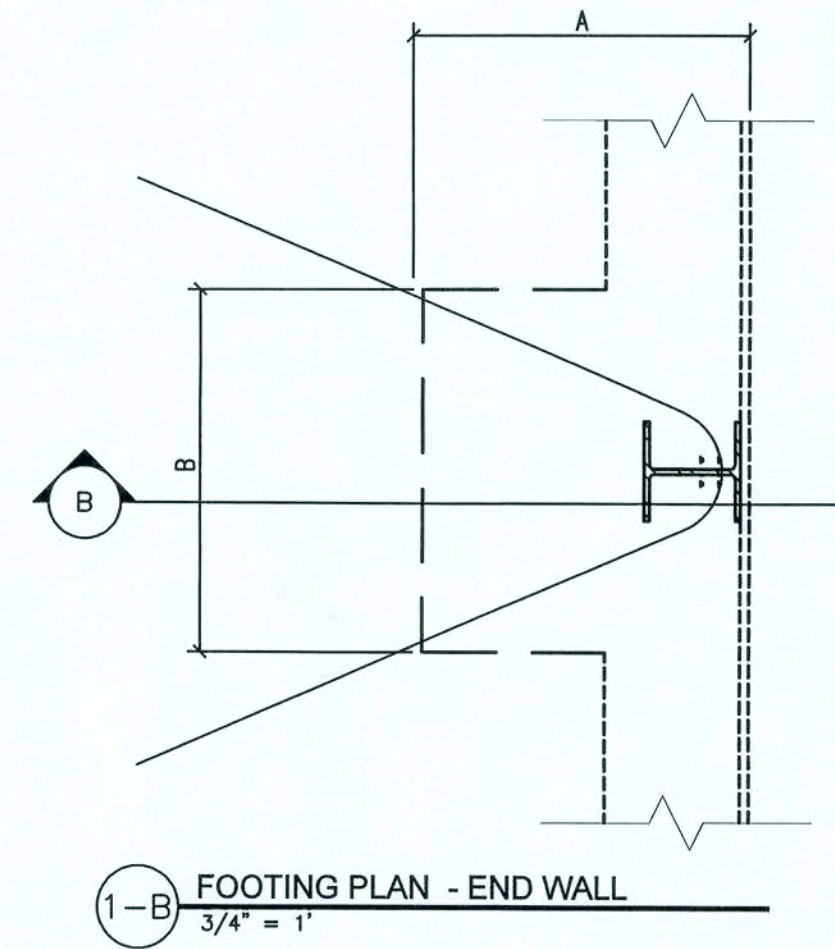


ISSUED FOR APPROVAL

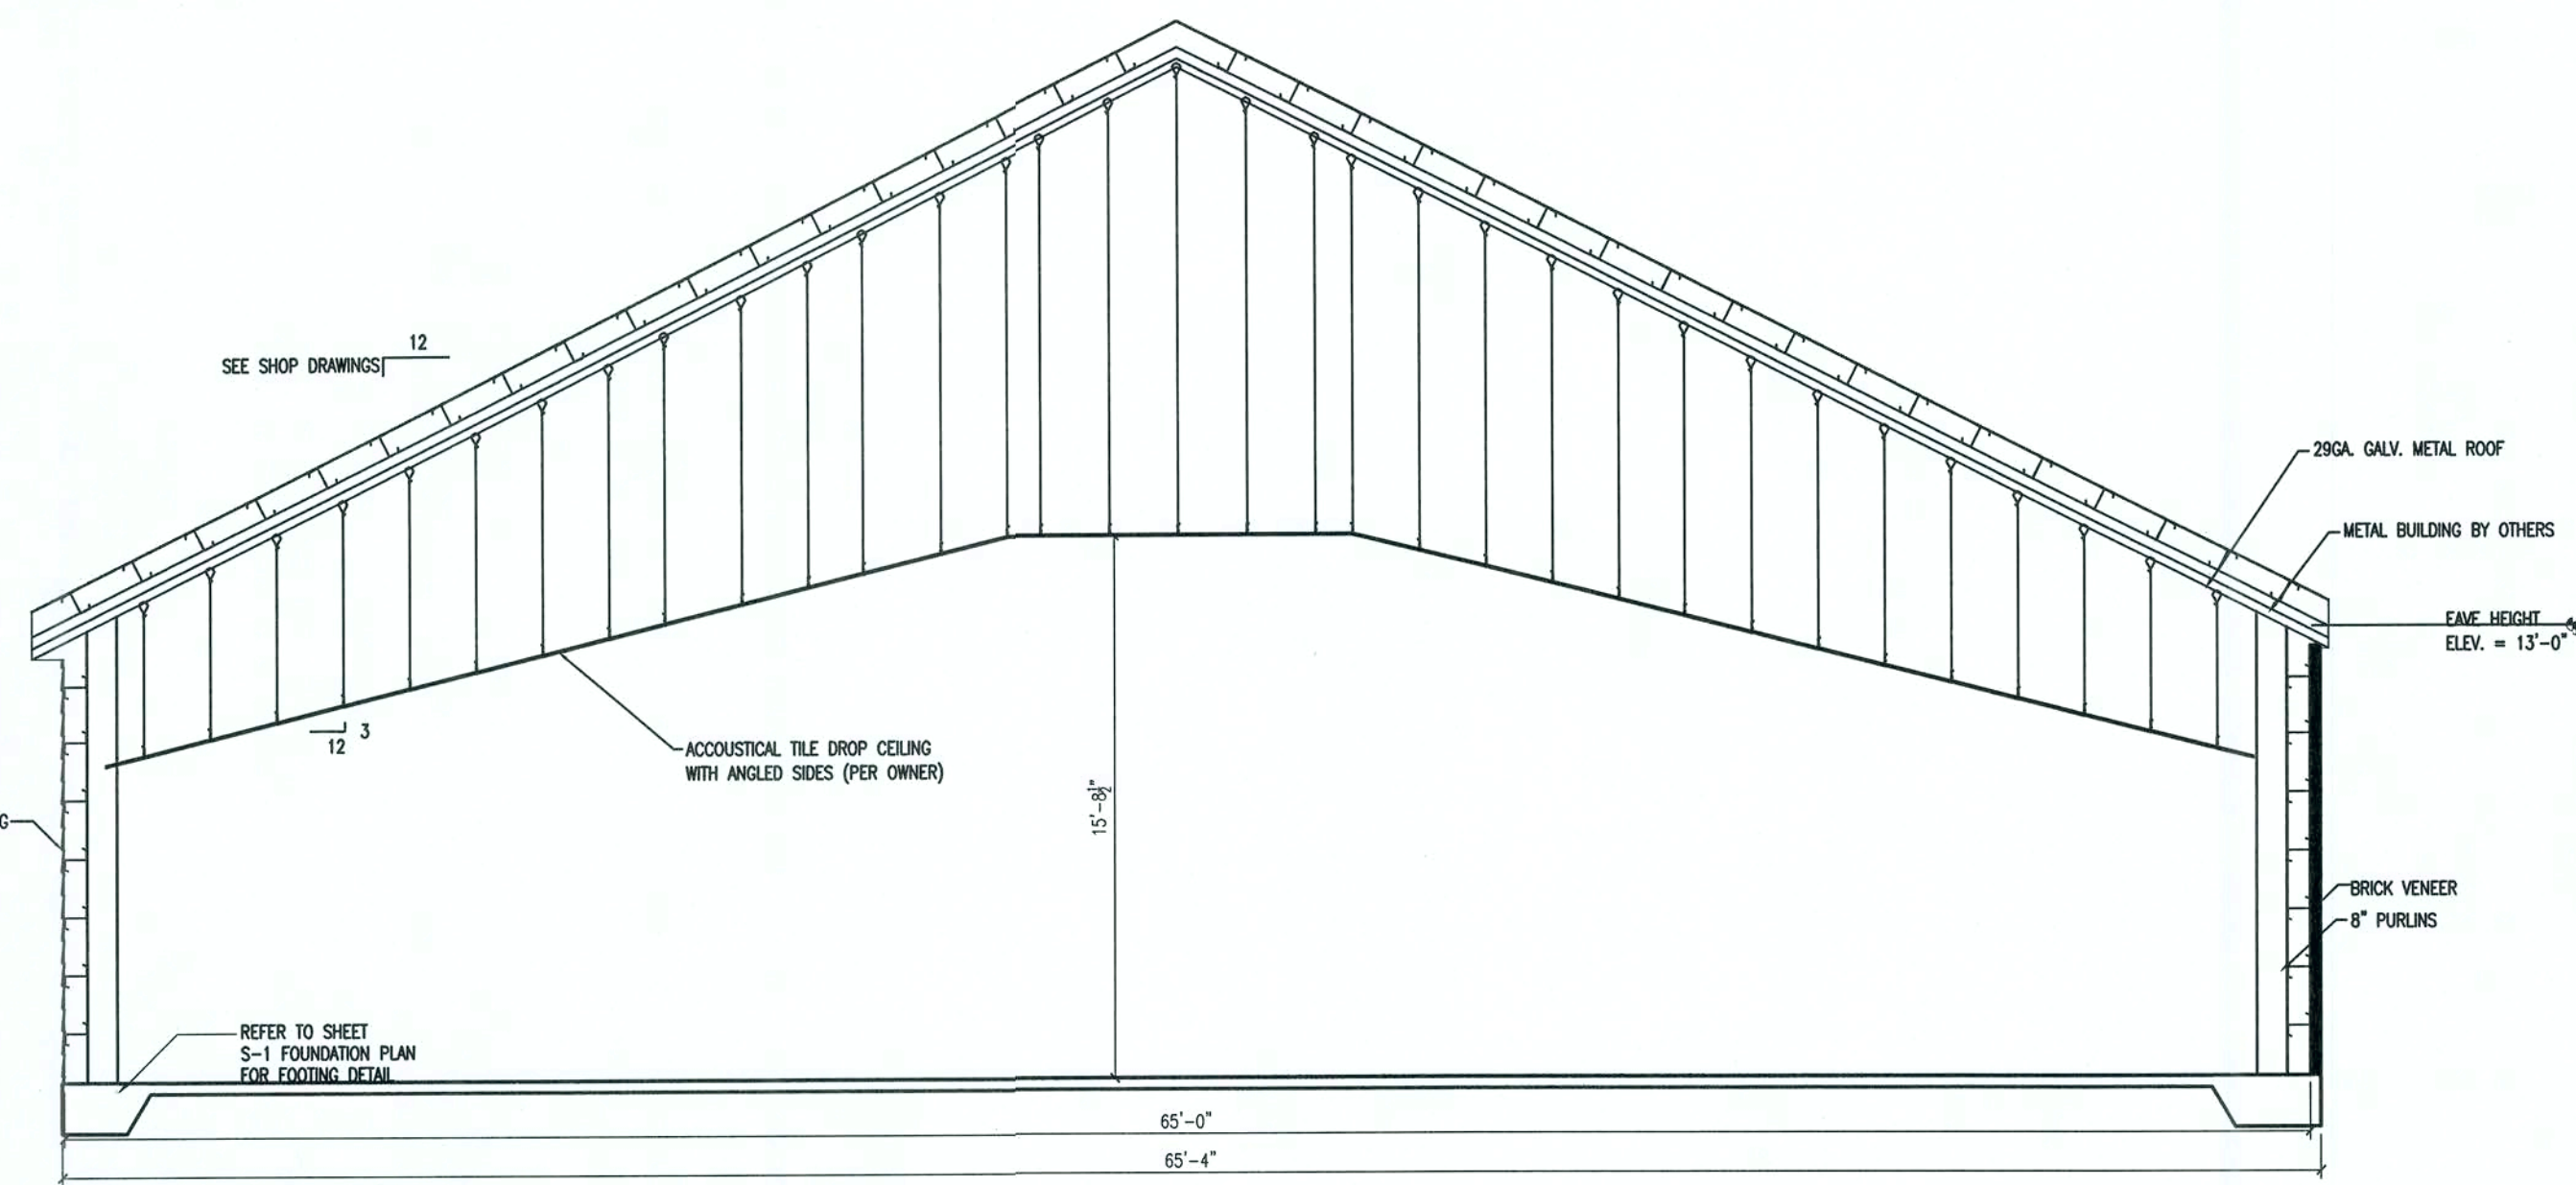


B SECTION - SANCTUARY
1/4\" = 1'

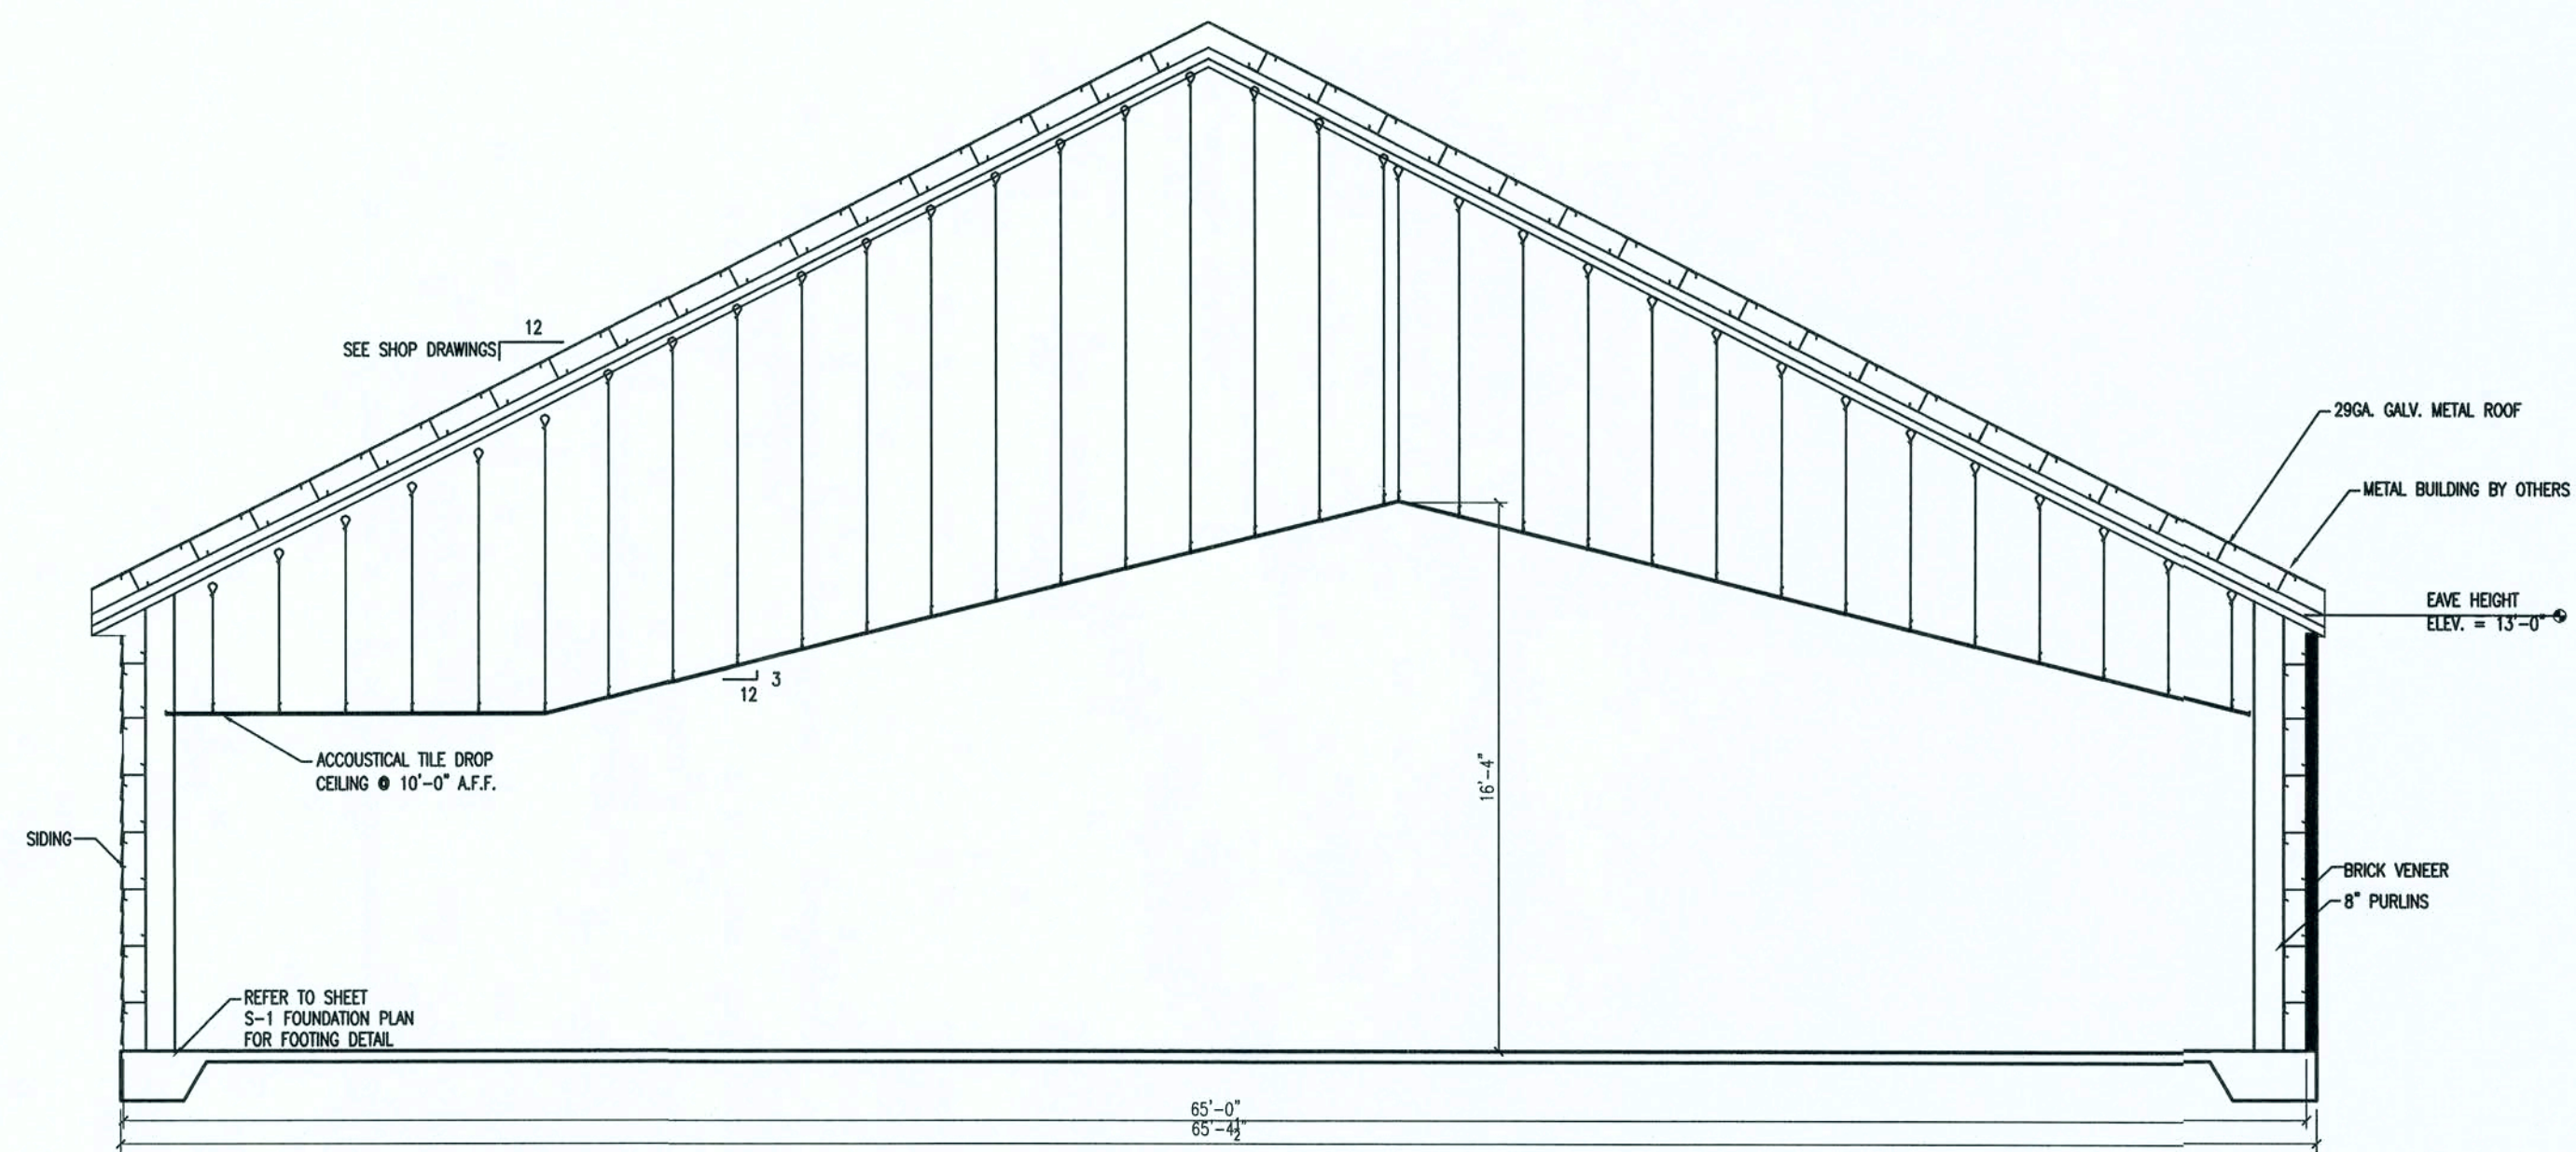

A COMMON AREA
1/4\" = 1'

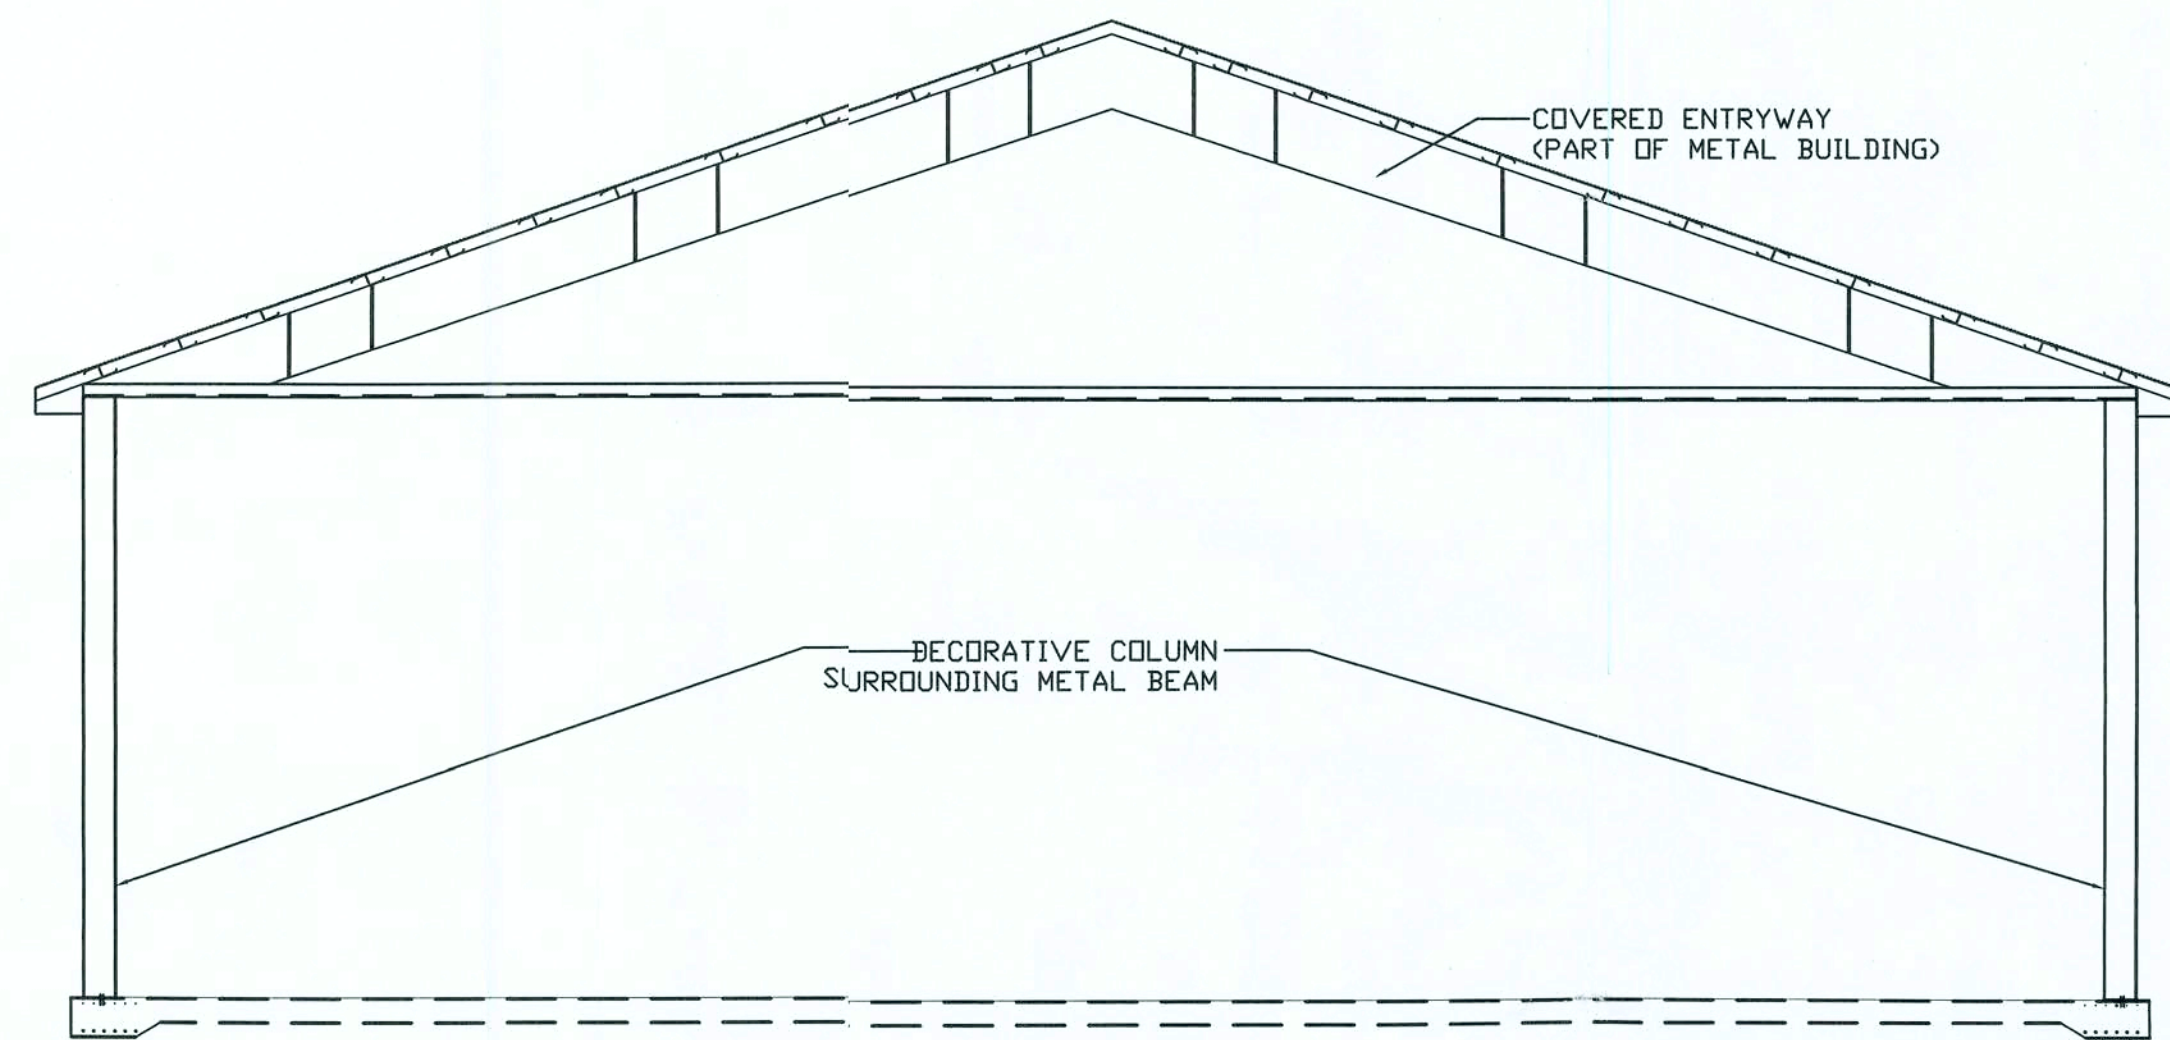

D COVERED ENTRYWAY
1/4\" = 1'

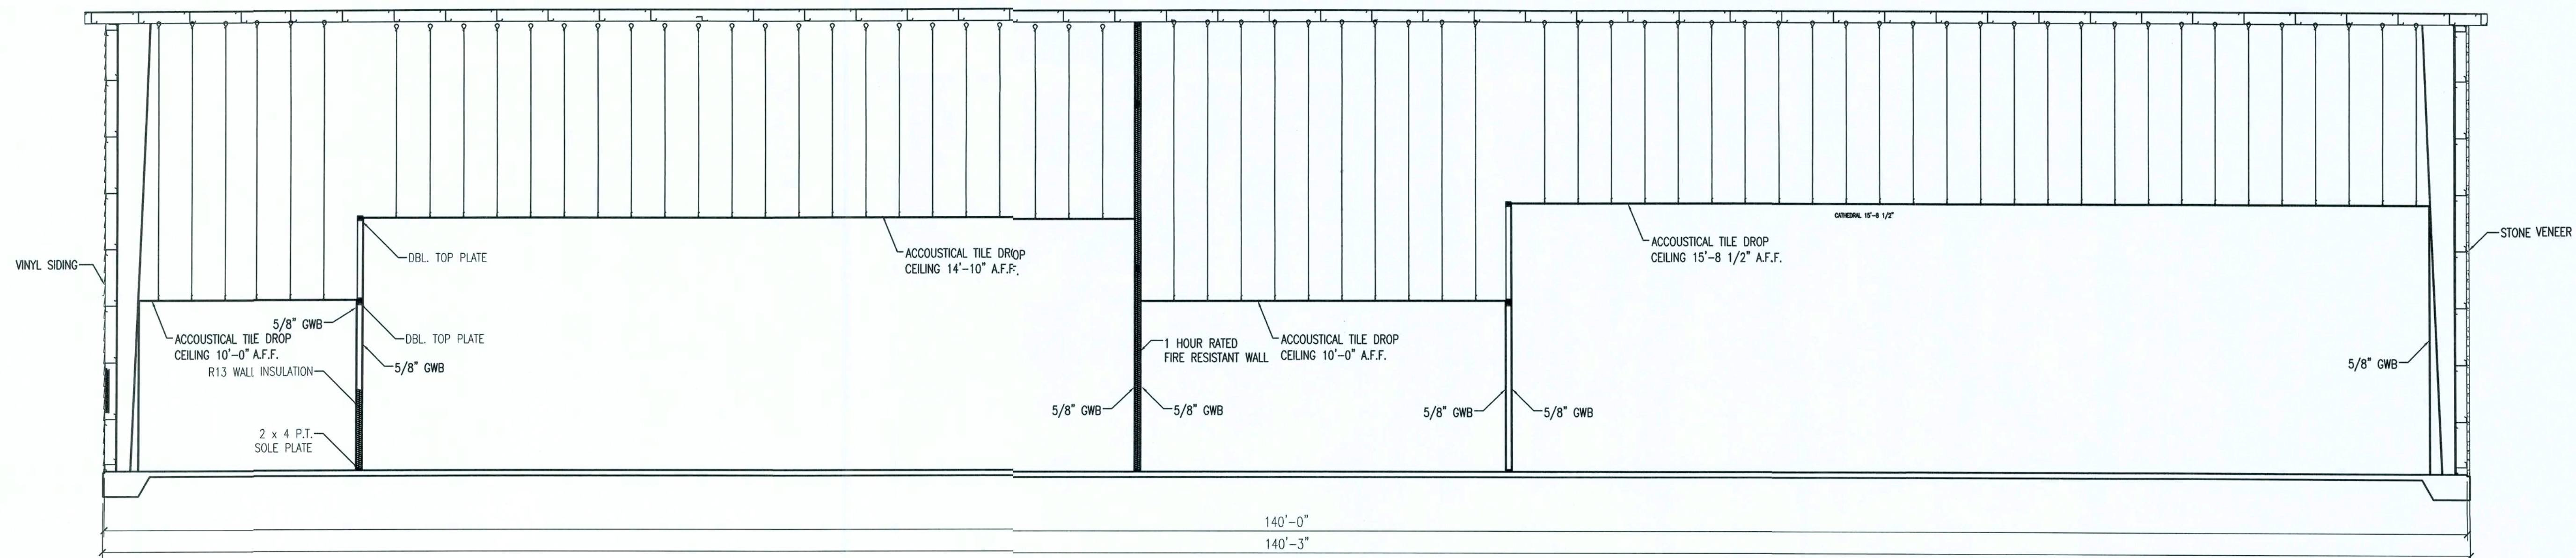

C SECTION - LONGITUDINAL
3/16\" = 1'-0"

ISSUED FOR APPROVAL

REV #	DATE	###	REVISION NOTES


P.O. Box 187
130 West Howard Street
Live Oak, FL 32064
Phone: (386) 362-3678
Fax: (386) 362-6133
Gary Gill, PE 51942
Auth. # 9461
STRUCTURAL CIVIL ENGINEERS

7TH DAY ADVENTIST CHURCH
NEW WORSHIP CENTER
COLUMBIA COUNTY, FLORIDA

SECTIONS

PROJECT NUMBER	PF06-193S
DRAWN BY	-
CHECKED BY	G.G.

S-2.0

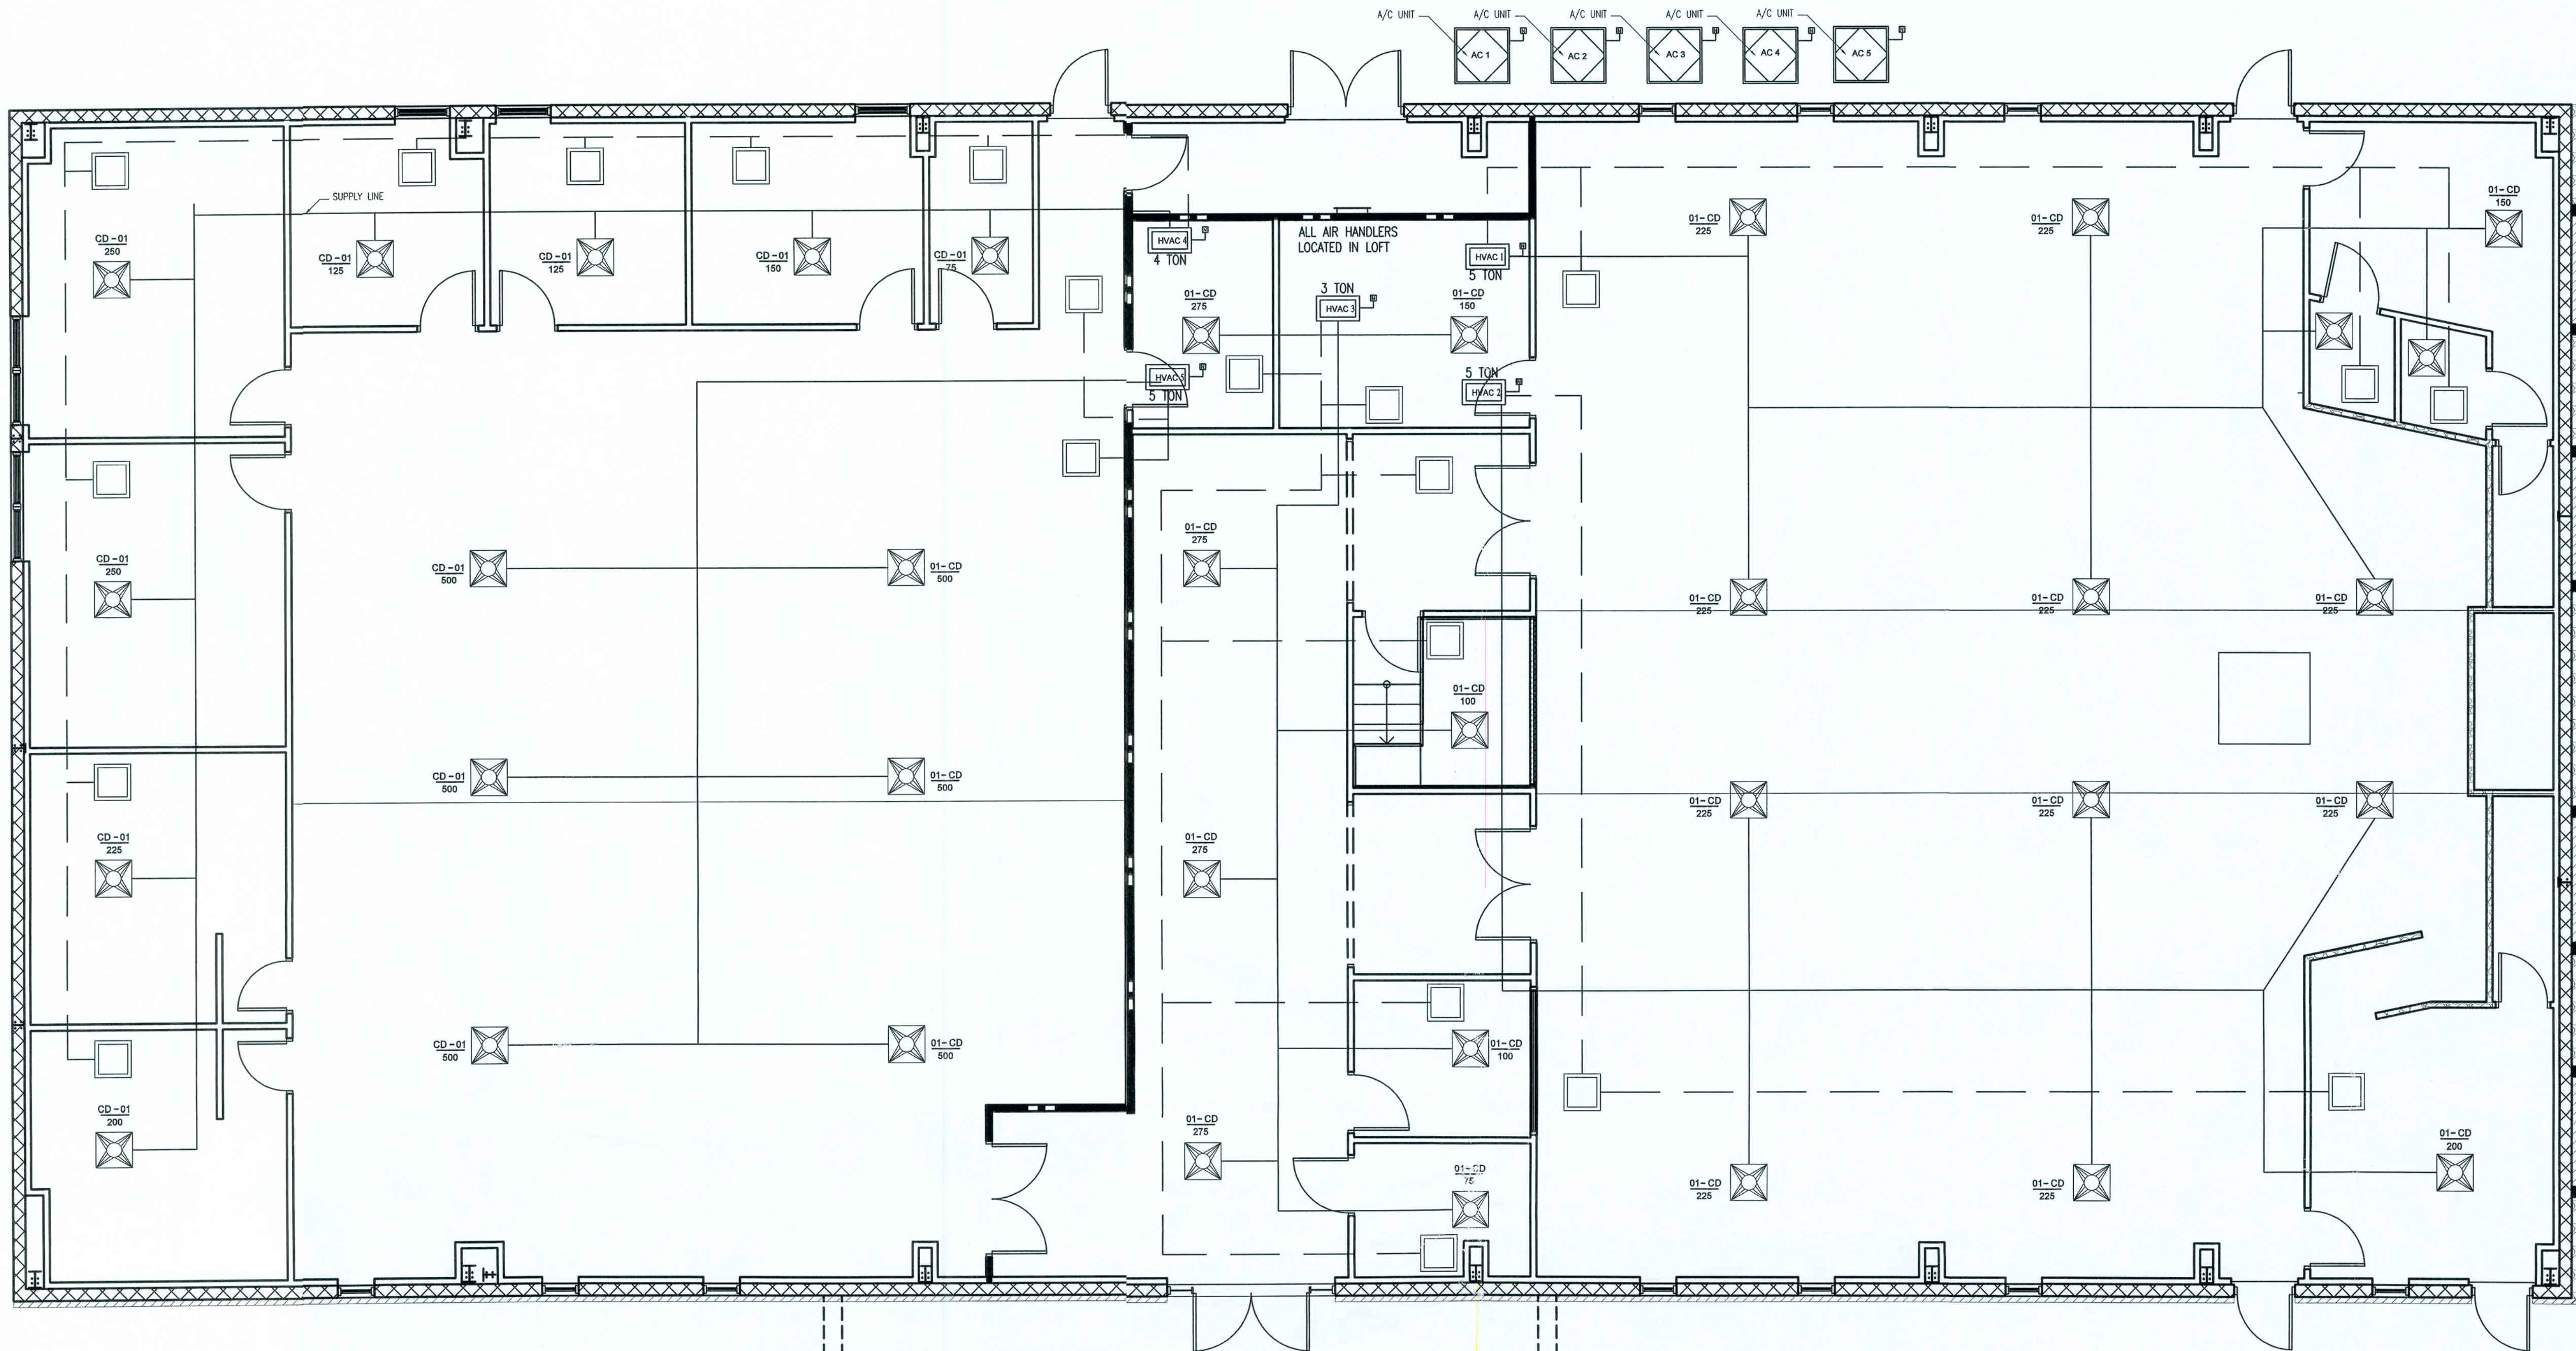

SPLIT SYSTEM - ELECTRIC HEAT												
QUANTITY	TAG	GOODMAN MODEL #S	INDOOR UNIT/OUTDOOR UNIT	NOMINAL TONS	TOTAL CFM	OA CFM	COIL EAT DB/WB	ESP	MAX FAN HP	TOTAL SENS. COOL MBH	SEER	HEAT ELEC KW NO. OF STAGES
3	ACU/AHU-1	GPC1306H21A/ARUF486016		5	2000	?	80/67	0.5	3/4	44.4	21.0	13.0
1	ACU/AHU-2	GPC1304H21A/ARUF486016		4	1600	?	80/67	0.5	3/4	44.4	21.0	13.0
1	ACU/AHU-2	GPC1305H21A/ARUF486016		3	1600	?	80/67	0.5	3/4	44.4	21.0	13.0

NOTES:

1. COOLING CAPACITIES BASED ON 95° F db air entering outdoor unit.
2. FAN COIL UNIT SHALL HAVE A SINGLE POINT POWER CONNECTION (FAN+HEAT).
3. COOLING CAPACITIES SCHEDULED ARE MINIMUM VALUES. ALTERNATIVE EQUIPMENT MUST MEET SCHEDULED VALUES.
4. SEER VALUE IS BASED ON ARI STANDARD 210.
5. ELECTRIC HEAT SHALL BE MOUNTED IN THE REHEAT POSITION.

ACCESSORIES

1. PROGRAMMABLE 7 DAY THERMOSTAT, WITH NIGHT SETBACK (55° HEATING, 85° COOLING), AUTO CHANGEOVER FOR HEAT-COOL, 5 DEGREE DECADEAN ADJUSTMENT.
2. PROVIDE (2) SETS OF STANDARD 1" THICK PLEATED THROW-AWAY FILTERS. (1) DURING CONSTRUCTION, (1) AFTER CONSTRUCTION COMPLETION.
3. PROVIDE FILTER DRYER
4. PROVIDE LONG LINE REFRIGERATION LINE SET WHERE REQUIRED BY MANUFACTURER.- LINES SHALL BE SIZED BY MANUFACTURER TO MAINTAIN SCHEDULED CAPACITY, SHOW MANUFACTURER'S RECOMMENDED LINE SET SIZE IN SUBMITTALS. MANUFACTURER SHALL DETERMINE IF LONG LINE APPLICATION KIT IS REQUIRED.
5. LOW AMBIENT OPERATION KIT TO ALLOW OPERATION DOWN TO 42 DEGREES


BASIS OF DESIGN: AS NOTED.

EQUAL BY: TRANE, YORK, LENNOX

CONTRACTOR SHALL CAREFULLY COORDINATE ALL RECESSED PROJECTOR LIGHTS WITH ALL DUCTWORK ABOVE CEILING PRIOR TO ANY DUCTWORK FABRICATION.

NOTE: These plans are schematic in nature and are intended to establish size, general routing and location, and performance and are not intended to show all possible conditions. All work shall be fully coordinated with other trades to insure the installation of a complete, operating system that fits in the space divided. Provide all labor, equipment, opportunities and materials necessary, and perform all operations required for the installation of complete, functional mechanical systems as outlined on the drawings and described in the specifications.

DUCT LEGEND	
	SUPPLY
	RETURN

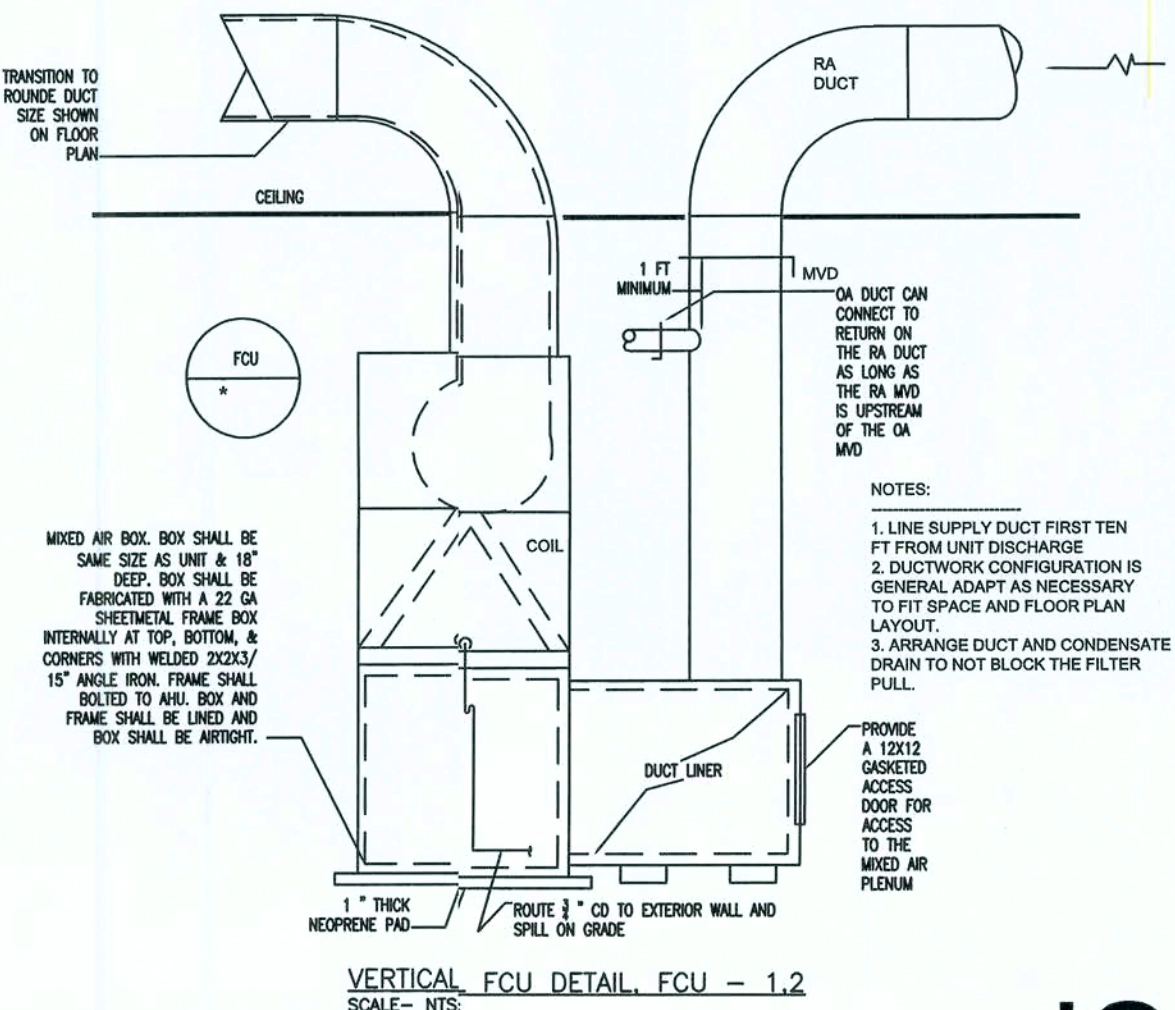

GENERAL MECHANICAL NOTES	
1. THE CONTRACTOR SHALL FURNISH ALL LABOR, MATERIALS, AND EQUIPMENT NECESSARY FOR THE INSTALLATION CODE AND ALL OPTION OF A COMPLETE SYSTEM IN WITH THESE DRAWINGS. THE APPLICABLE BUILDING CODE AND ALL OTHER APPLICABLE STATE, COUNTY AND LOCAL ORDINANCES AND THE LATEST ADDITION OF THE FOLLOWING PUBLICATIONS, ASHREA, NFPA 90A, 90B, 91, AND ANSI 8-8.1 MECHANICAL REFRIGERATION. 2. THE CONTRACTOR SHALL PAY ALL COSTS OF PERMIT, INSPECTIONS, AND ALL OTHER COSTS INCIDENTAL TO THE COMPLETION AND TESTING OF THIS WORK. 3. THE PLUMBING CONTRACTOR SHALL VISIT THE SITE AND THOROUGHLY FAMILIARIZE HIMSELF WITH ALL EXISTING CONDITIONS, ALL EXECUTION AND BACKFILL AS REQUIRED FOR THIS PHASE OF CONSTRUCTION SHALL BE A PART OF THIS CONTRACT. 4. THE CONTRACTOR SHALL SUPPLY THE ENGINEER/ARCHITECT WITH AS-BUILT DRAWINGS UPON COMPLETION OF THIS PROJECT. 5. CONTRACTOR SHALL SUBMIT FOR APPROVAL FIVE (5) COPIES OF MANUFACTURER'S DRAWING FOR EACH PIECE OF EQUIPMENT AND CONTROLS INCLUDED IN CONTRACT. 6. ALL MATERIAL SHALL BE NEW OF GOOD QUALITY. ALL WORK SHALL BE PERFORMED IN A WORKMANLIKE MANNER BY SKILLED WORKMAN. 7. ALL AIR CONDITIONING DUCT SHALL BE OF 1-1/2" STANDARD DUTY FOIL REINFORCED FIBERGLASS WITH MANUFACTURER'S LOGO PRINTED ON THE VAPOR BARRIER. ALL FLEX TO BE R-8. 8. ALL EXHAUST DUCTS AND OUTSIDE AIR DUCTS SHALL BE GALVANIZED SHEET METAL WITH SEALED SEAMS AND JOINTS. 9. DUCT SIZES SHOWN ARE INSIDE DIMENSIONS. 10. ALL AIR DEVICES (DIFFUSERS, REGISTERS, AND GRILLS) SHALL BE ALL ALUMINUM CONSTRUCTION WITH EXPOSED SURFACE OFF WHITE BAKED ENAMEL FINISH OR AS SPECIFIED BY ENGINEER/ARCHITECT. DEVICES SHALL BE TITLUS, METALARE, AND AIRGUIDE. PROVIDE OPPOSED BLADE DAMPERS AT ALL DIFFUSERS AND REGISTERS. 11. THERMOSTAT SHALL BE COMBINATION COOLING/HEATING, WITH SYSTEM "COOL-AUTO-HEAT-OFF" AND FAN "ON-AUTO" SELECTOR SWITCHES. PROVIDE PROGRAMMABLE TYPE, CARRIER OR EQUAL. 12. REFRIGERANT LINES SHALL BE COPPER, TYPE "L" HARD DRAWN WITH WRIGHT COOPER SOLDER JOINT TYPE FITTINGS. USE 95/5 SOLDER. REFRIGERANT LINES SHALL BE SIZED AS PER MANUFACTURER RECOMMENDATIONS. 13. ARMAFLEX 3/4" INSULATION SHALL BE USED FOR SUCTION LINES, FILTER/DRYER AND SIGHT GLASS SHALL BE PROVIDED AT LIQUID LINES. 14. ALL BRANCH TAKE-OFFS TO BE PROVIDED WITH MANUAL VOLUME DAMPERS. ALL ELBOWS AND TEES MUST BE FURNISHED WITH TURNING VANES. PROVIDE 45 DEGREE BRANCH TAKE-OFF AS PER BRANCH DUCT TAKE-OFF DETAIL.	15. PROVIDE NEW FILTERS FOR ALL AIR CONDITIONING EQUIPMENT BEFORE STARTING THEM. REPLACE THEM PRIOR TO ACCEPTANCE BY OWNER. 16. PROVIDE SMOKE DETECTORS WITH ACCESS DOORS IN ALL SUPPLY AIR DUCTS FOR FANS AND AHUS SERVING A COMMON PLENUM OF 200 CFM OR ABOVE. ALL SMOKE DETECTORS SHALL BE BY ONE MANUFACTURER, COORDINATE VOLTAGE ETC. WITH ELECTRICAL CONTRACTOR AND FIRE ALARM SYSTEM BEFORE ORDERING. 17. PROVIDE TYPE "B" FIRE DAMPERS IN ALL DUCTS OR OPENINGS PENETRATING FIRE RATED WALLS, MECHANICAL AND ELECTRICAL ROOMS, TENANT SEPARATION, PARTITIONS, FLOOR OR ROOF SLABS AND AT OIA INTAKES. PROVIDE RADIATION DAMPERS IN RATED CEILING FOR ALL CEILING OPENING, CEILING FANS, DIFFUSERS OR GRILLS RATED FOR USE IN THE CEILING ASSEMBLY. 18. HVAC CONTRACTOR SHALL PROVIDE AN INDEPENDENT TEST AND BALANCE REPORT FOR ALL MECHANICAL EQUIPMENT, AIR DEVICE, DAMPERS, AHUS AND FANS. THE TAB SHALL BE IN ACCORDANCE WITH THE AIR BALANCE COUNCIL STANDARDS AND SHALL INCLUDE AIR QUANTITIES FOR ALL SUPPLY GRILLS, RETURN GRILLS, AND EXHAUST GRILLS AND LEAVING AND ENTERING AIR TEMPERATURE FROM THE SUPPLY GRILLS AND EVAPORATORS. 19. THERMOSTAT LOCATION SHALL BE APPROVED BY OWNER AND ENGINEER/ARCHITECT BY INSTALLATION. 20. ALL INSULATION WILL HAVE FIRE/SMOKE RATING LESS THAN 500R. 21. MECHANICAL PLANS IN GENERAL, ARE DIAGRAMMATIC IN NATURE, AND ARE TO BE READ IN CONJUNCTION WITH ARCH, PLUMBING, ELECTRICAL, AND STRUCTURAL PLANS AND SHALL BE CONSIDERED AS ONE SET OF DOCUMENTS. DUCT AND PIPING OFFSETS, BENDS AND TRANSITIONS WILL BE REQUIRED TO PROVIDE AND INSTALL A COMPLETE FUNCTIONAL SYSTEM AND SHALL BE PROVIDED BY THE CONTRACTOR AT NO ADDITIONAL COST TO THE OWNER. 22. NO COMBUSTIBLE MATERIALS ARE ALLOWED IN RETURN AIR PLENUMS OR ABOVE CEILINGS USED AS RETURN AIR PLENUM. IF SPACE WITH RETURN AIR PLENUM HAS ANY DECK PARTITION, AIR TRANSFER DUCTS MUST BE INSTALLED. 23. REFER TO PLUMBING PLAN FOR CONDENSATE PIPING. 24. IF PROJECT IS A REMODEL OF AN EXISTING BUILDING, THE CONTRACTOR SHALL VISIT JOB SITE PRIOR TO CONSTRUCTION AND COORDINATE ALL FIELD CONDITIONS. ENGINEER AND/OR ARCHITECT SHALL BE NOTIFIED OF ANY DISCREPANCIES. 25. CONTRACTOR SHALL INSTALL ALL OUTDOOR EQUIPMENT TO WITHSTAND A SUSTAINED 200 MPH WIND WITH A GUST FACTOR OF 30%. PROVIDE A LISTED PRE-ENGINEERED ASSEMBLY, OR CONTRACTOR SHALL BE RESPONSIBLE FOR THE CERTIFICATION OF ROOF MOUNTING. 26. PROVIDE ALL NECESSARY CONTACTS, RELAYS, ETC., FOR A COMPLETE OPERATING A/C SYSTEM.

ISSUED FOR APPROVAL

7TH DAY ADVENTIST CHURCH
NEW WORSHIP CENTER
COLUMBIA COUNTY, FLORIDA

MECHANICAL PLAN

PROJECT NUMBER
PF06-1935
DRAWN BY
-
CHECKED BY
G.G.
M-1

REVISION NOTES


REV #	DATE	###

P.O. Box 187
130 West Howard Street
Live Oak, FL 32060
Phone: (386) 362-6133
Fax: (386) 362-6133
Auth: # 51942

STRUCTURAL/CIVIL ENGINEERS
GARY GILL, P.E.

9/5/07

SHEET 11 OF 16

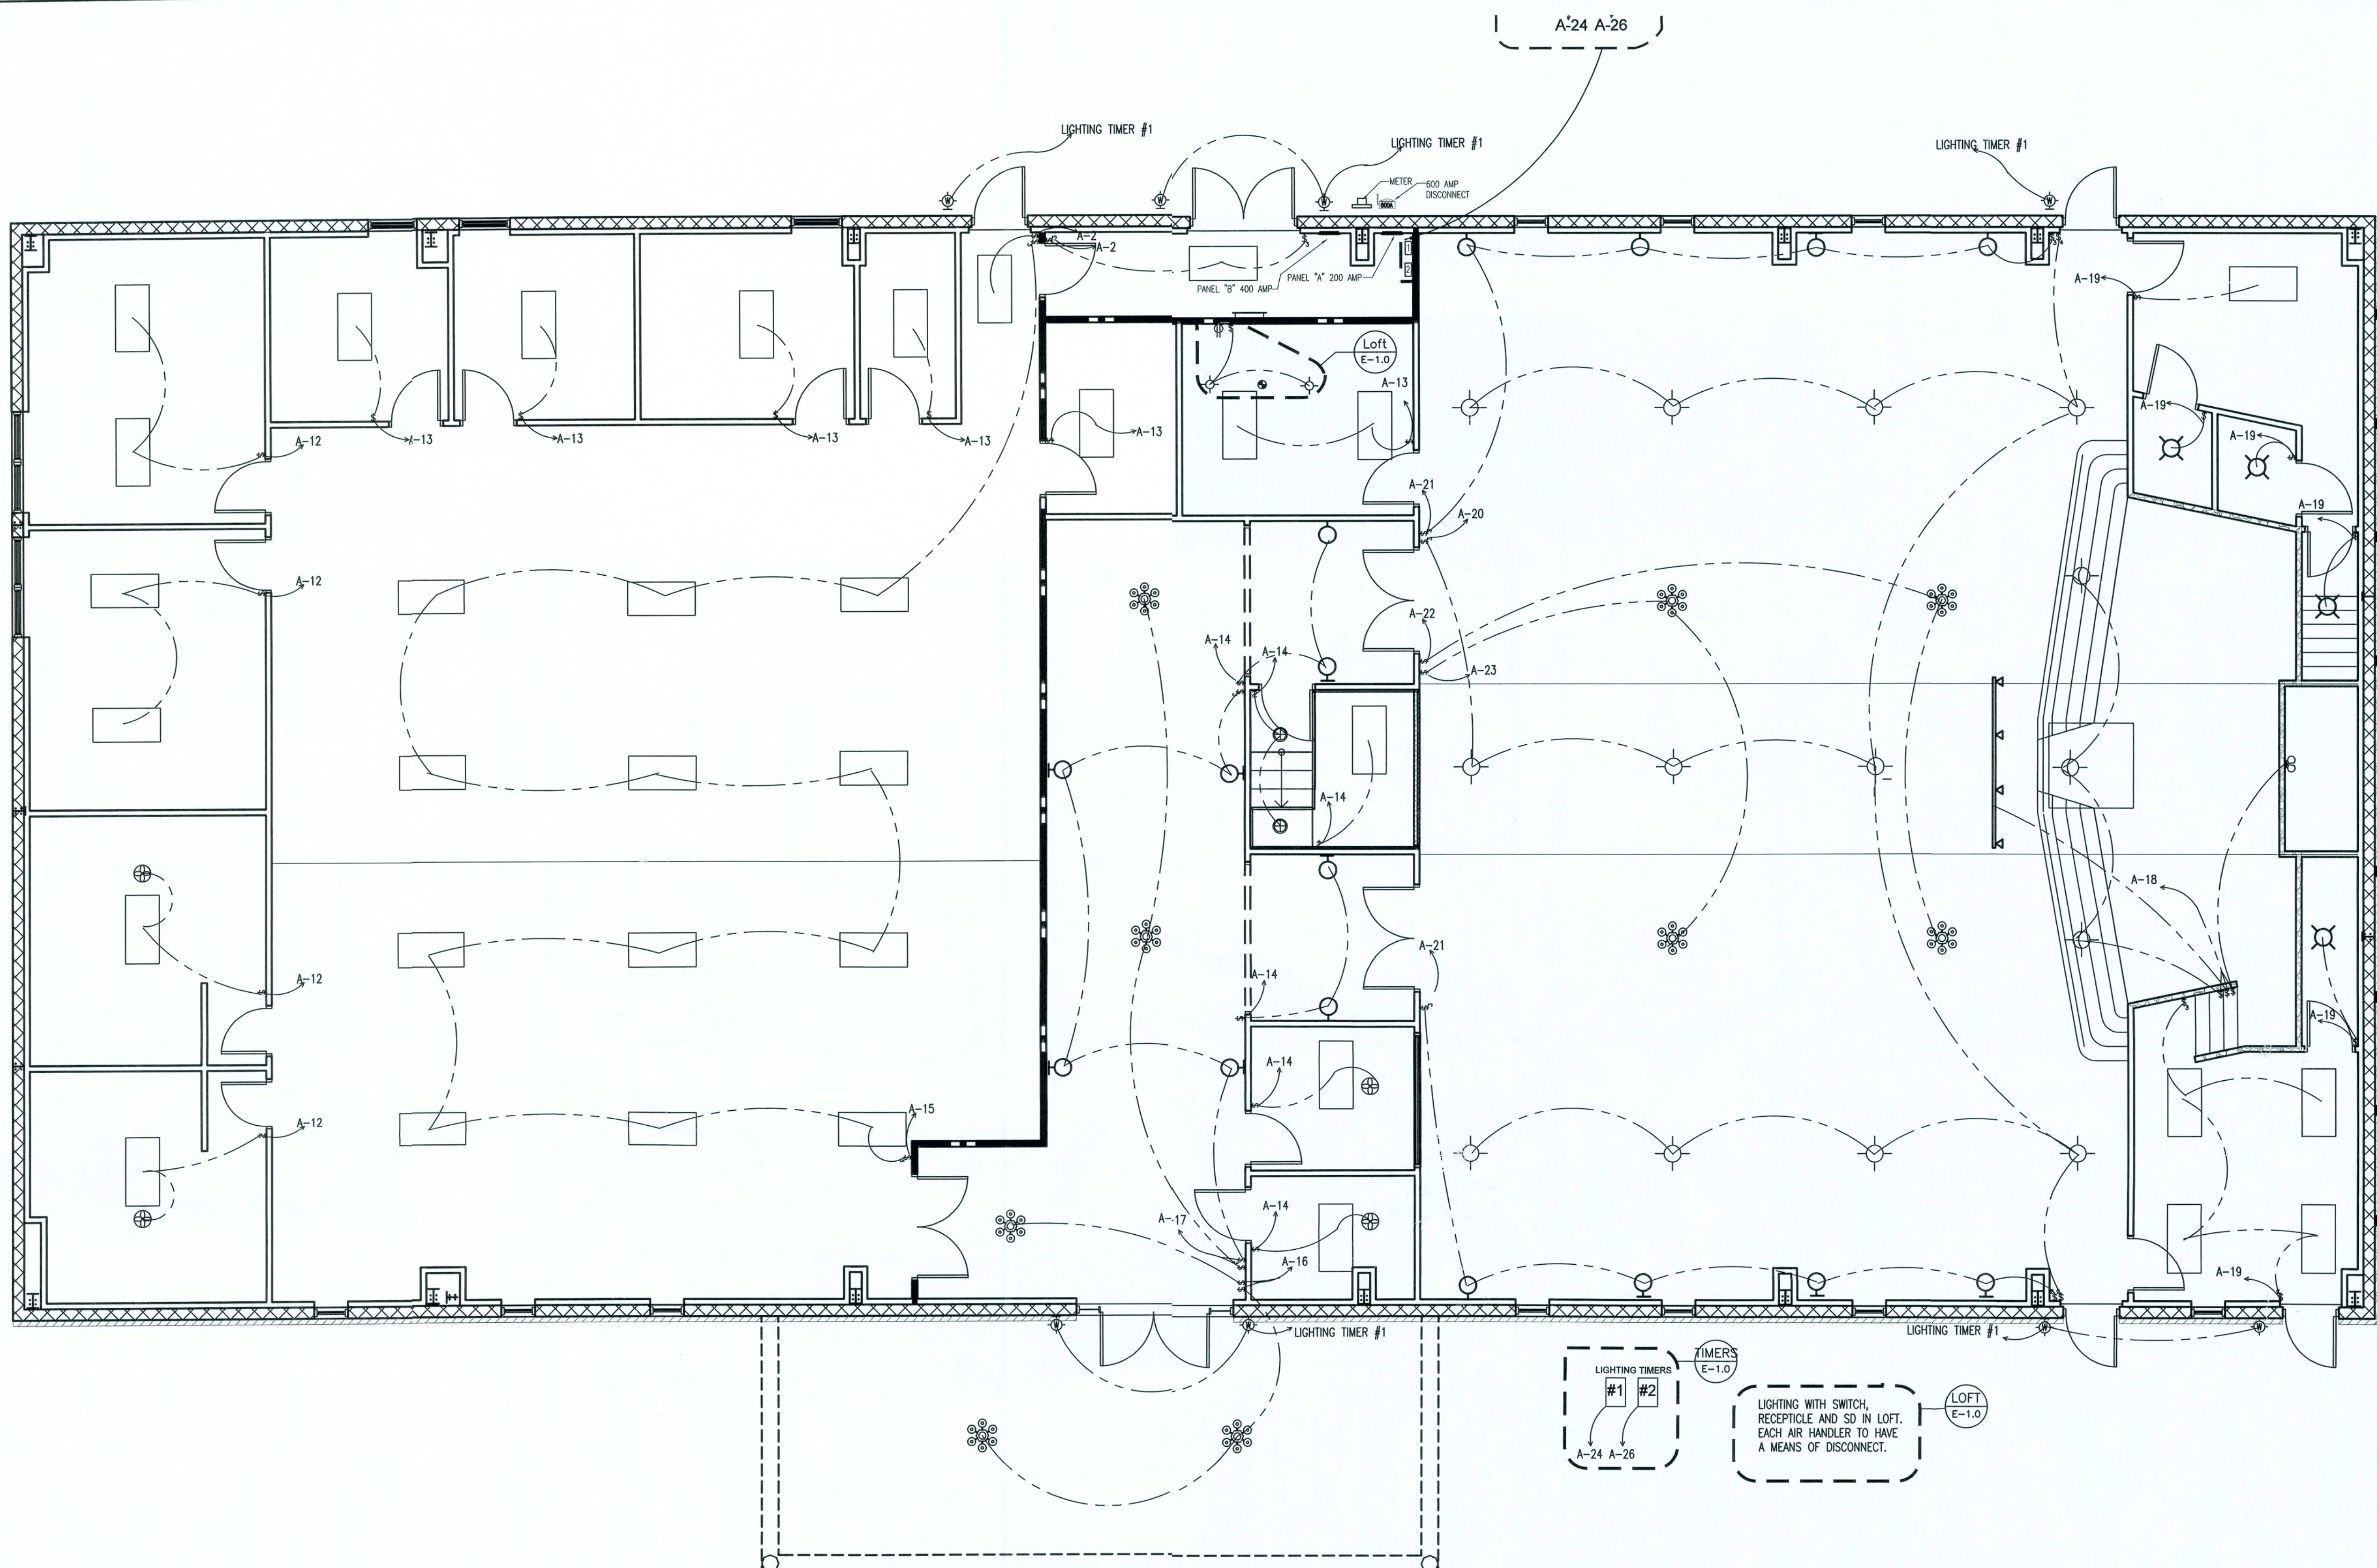

LIGHTING PLAN
SCALE: 3/16" = 1'-0"

ELECTRICAL LEGEND		
SYMBOL	QUANTITY	DESCRIPTION
	11	SPOT LIGHT
	3	DIRECTIONAL SPOT LIGHT
	9	DECORATIVE HANGING CHANDELIER
	47	FLUORESCENT LIGHT
	3	EXHAUST FAN
	8	COACH LIGHT
	29	SINGLE POLE SWITCH
	14	3 WAY SWITCH
	1	4 WAY SWITCH
	1	METER
	2	PANEL W/ MAIN BREAKER
	2	RECESSED CAN LIGHT
	2	SURFACE MOUNT GLOBE LIGHT
	2	FLOOD LIGHTS

ISSUED FOR APPROVAL

REVISION NOTES

REV #	DATE	ISSUED FOR
1	10-20-06	CONSTRUCTION


P.O. Box 187
130 West Howard Street
Live Oak FL 32064
Phone: (386) 362-3678
Fax: (386) 362-6133

STRUCTURAL CIVIL ENGINEERS

7th ADVENTIST CHURCH
NEW WORSHIP CENTER
COLUMBIA COUNTY, FLORIDA

LIGHTING PLAN

PROJECT NUMBER
PF06-193S
DRAWN BY
D. PRICE
CHECKED BY
G.G.
E-1.0
SHEET 12 OF 16

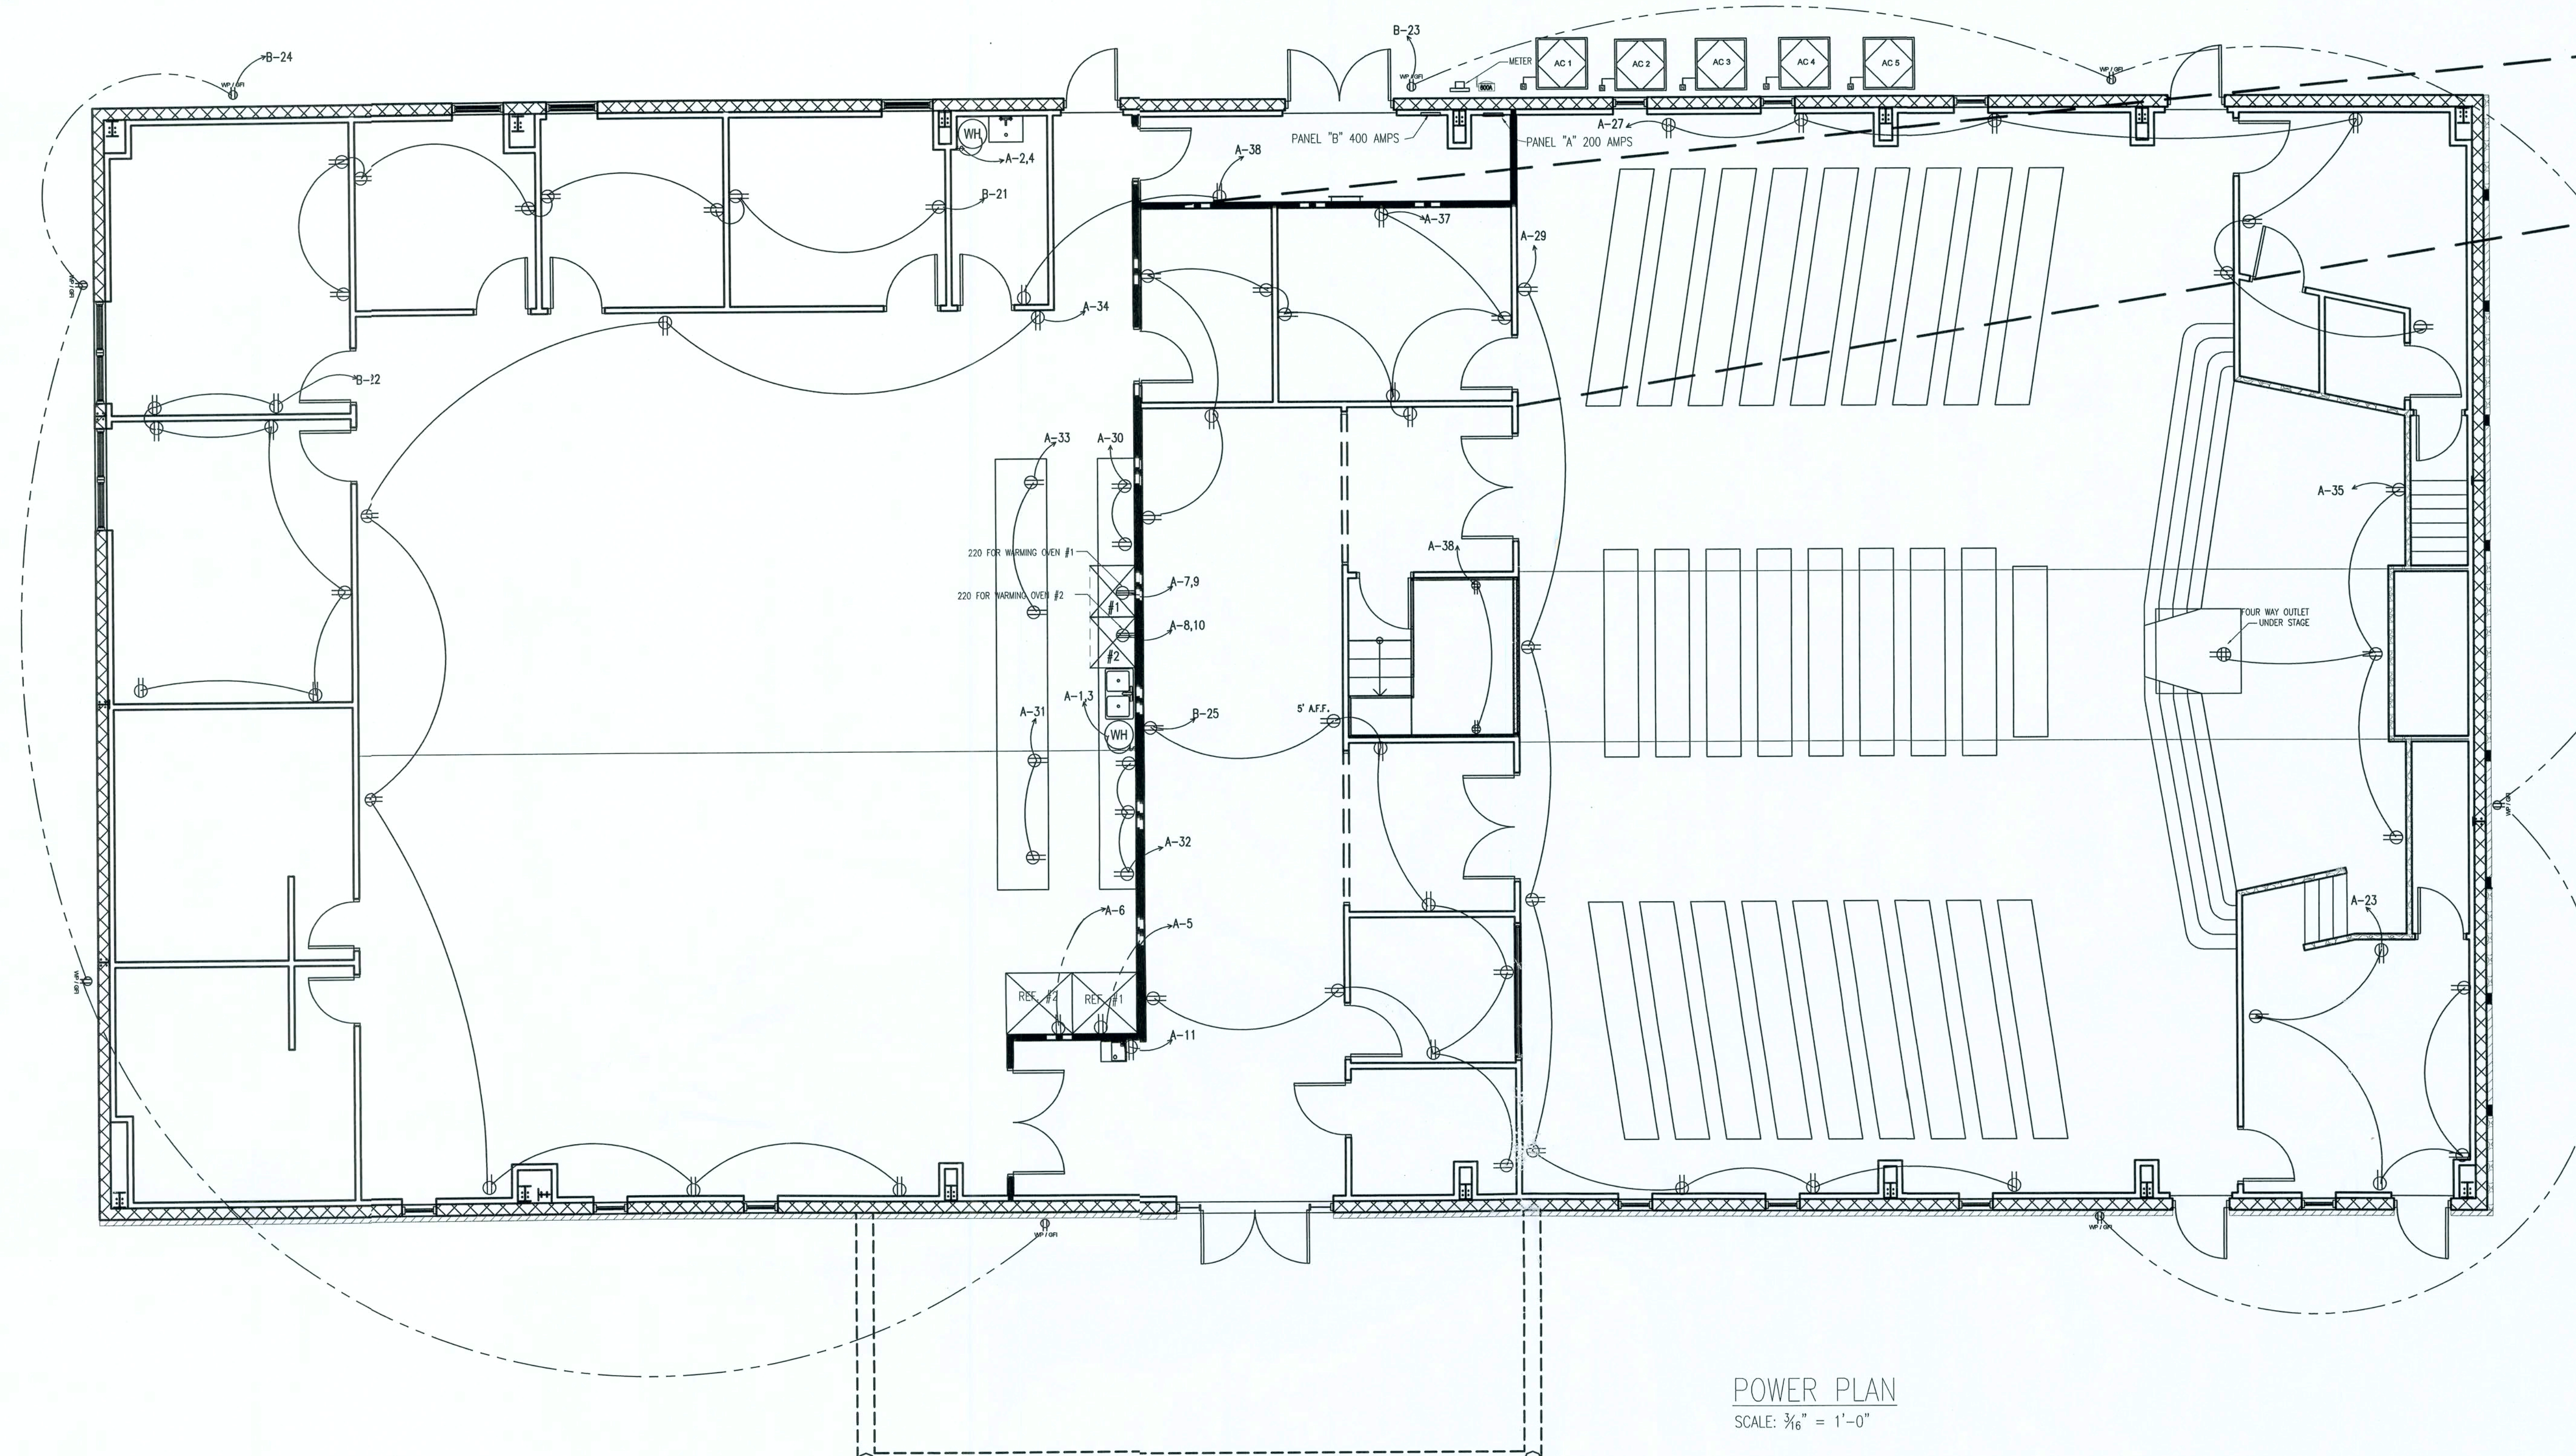

ELECTRICAL LEGEND		
SYMBOL	QUANTITY	DESCRIPTION
(M)	1	STANDARD OUTLET

POWER PLAN
SCALE: $\frac{3}{16}'' = 1'-0''$

ISSUED FOR APPROVAL

31-Aug-07

7/5/07

7TH DAY ADVENTIST CHURCH
NEW WORSHIP CENTER
COLUMBIA COUNTY, FLORIDA

POWER PLAN


PROJECT NUMBER	PF06-193S
DRAWN BY	-
CHECKED BY	G.G.
E-1.1	

SHEET 13 OF 16



P.O. Box 187
130 West Howard Street
Live Oak FL 32064
Phone: (386) 362-3678
Fax: (386) 362-6133
Auth. # 9461


REV #	DATE	REVISION NOTES
###	###	###

 

31-Aug-07

L
9/5/07

PROJECT NUMBER	PF06-193S
DRAWN BY	-
CHECKED BY	G.G.
P-1	
SHEET 15 OF 16	

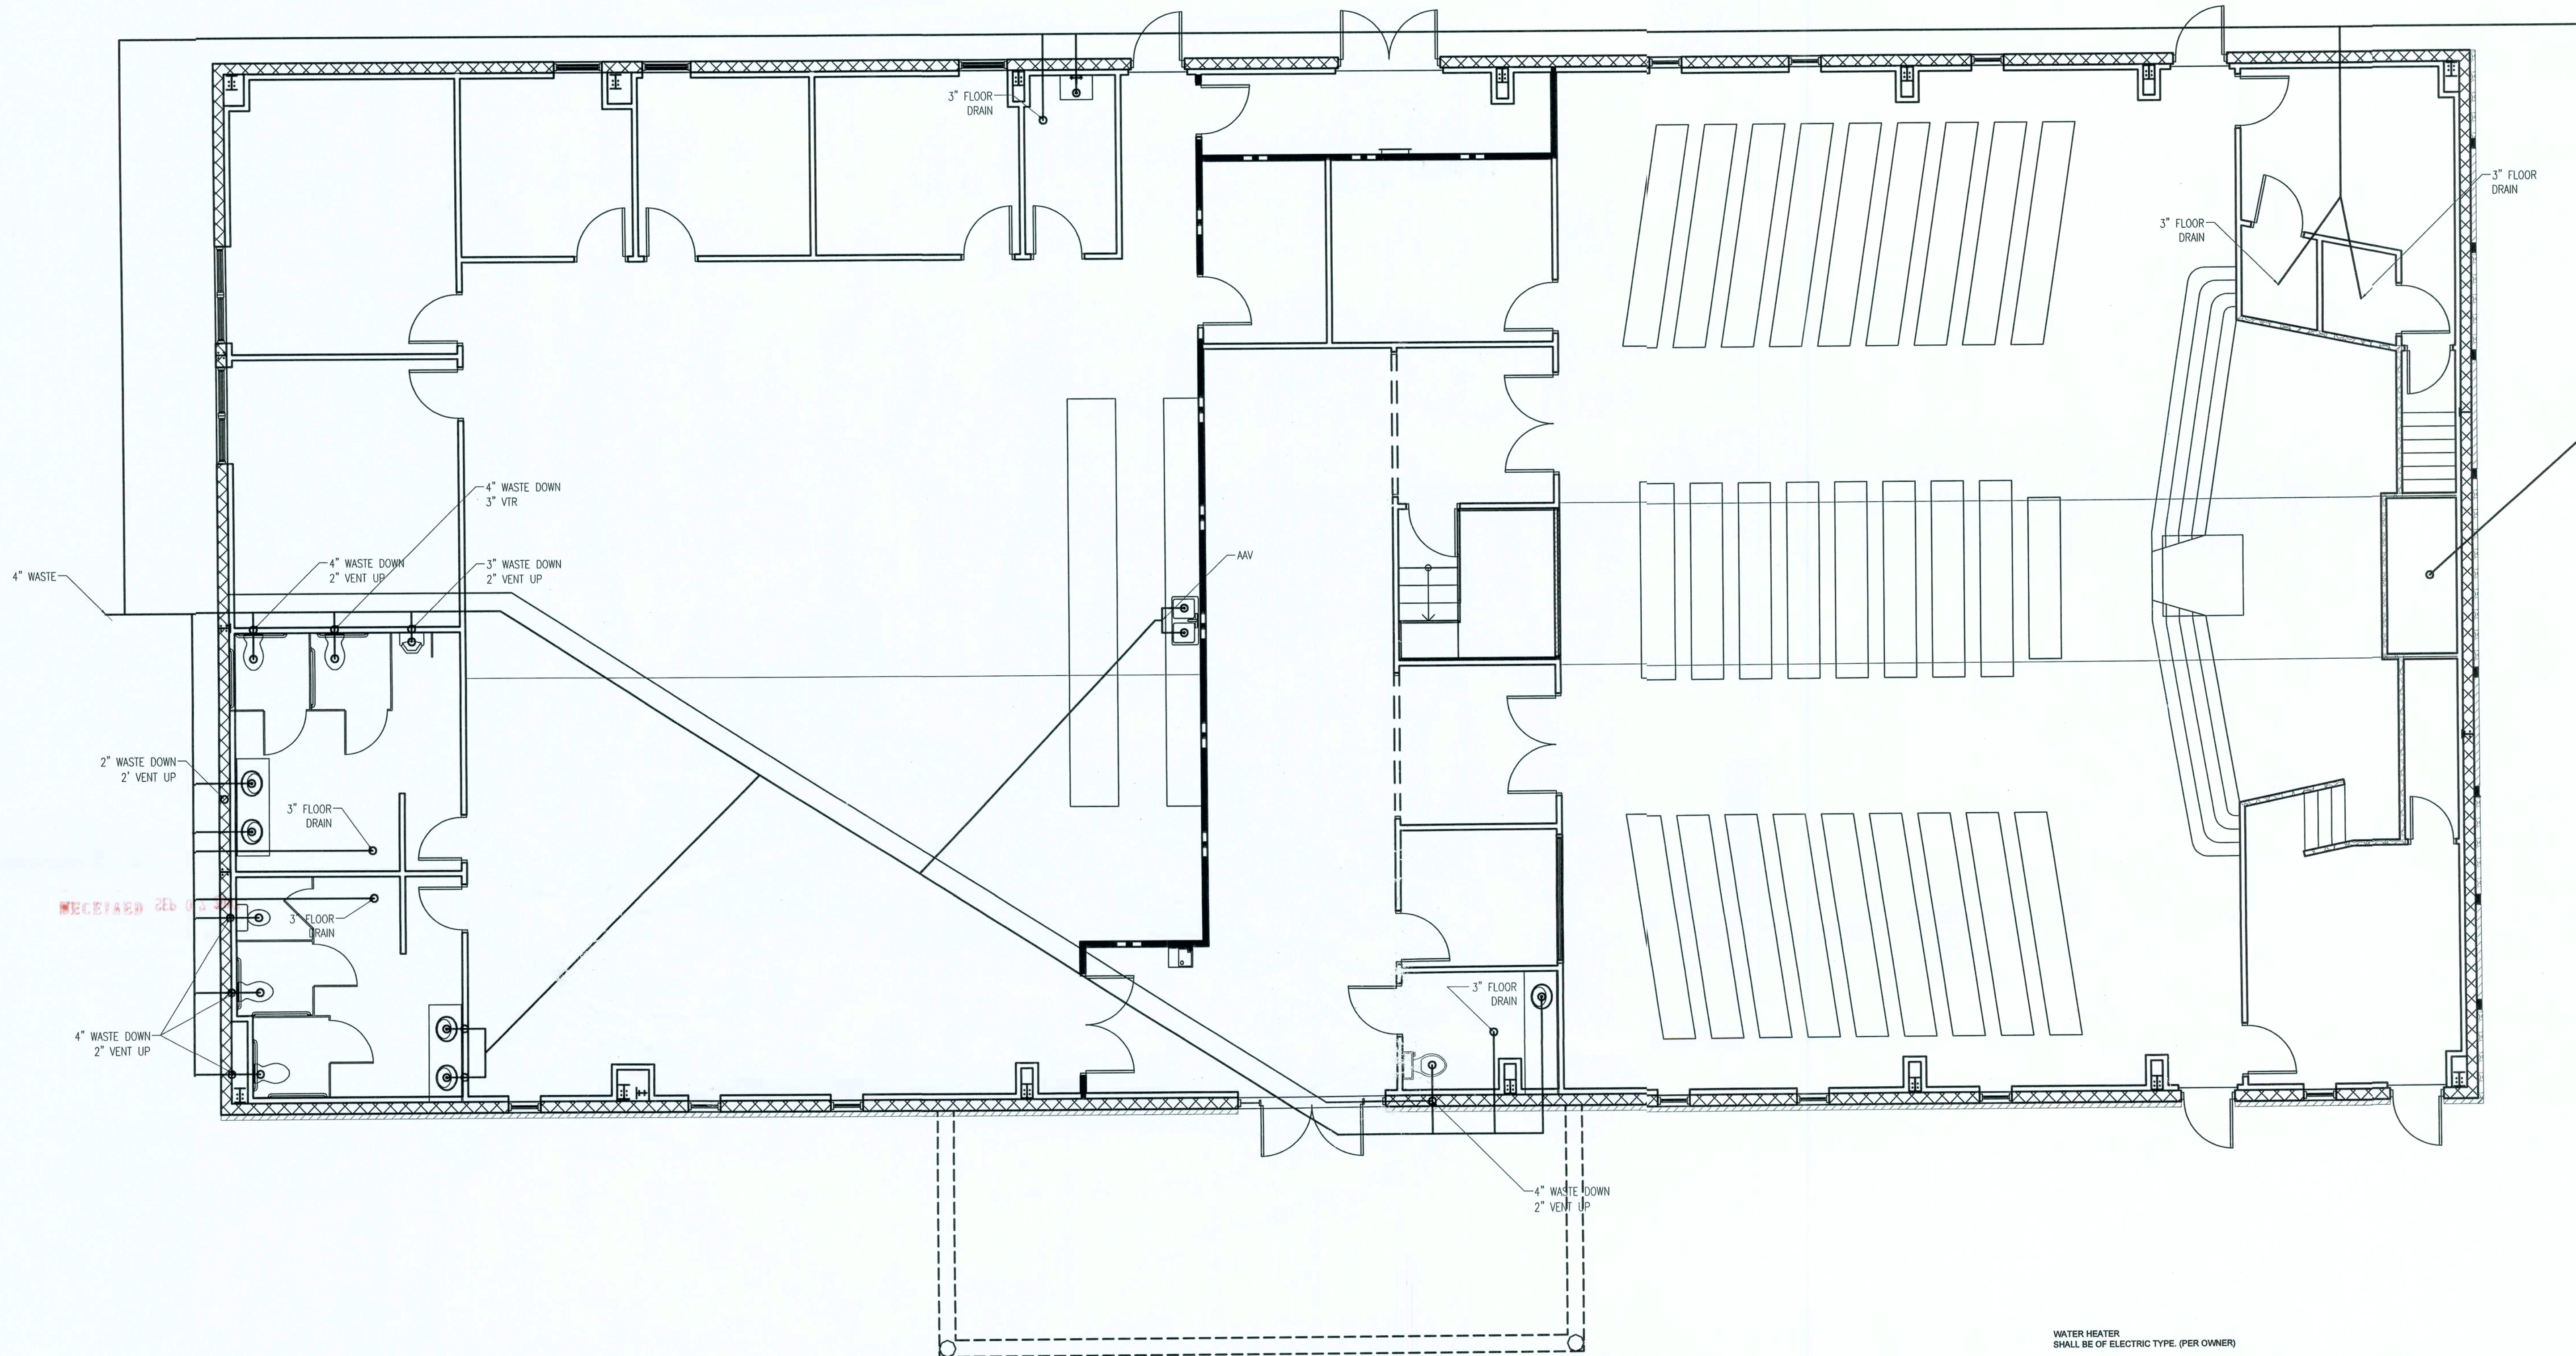


FIXTURES:

F1 = LAVATORY
F2 = WATER CLOSET
F3 = FLOOR DRAIN
F4 = SINK
F5 = URINAL
FD = FLOOR DRAIN

NOTES:

1. SOIL PIPING, VENTS, AND STACK TO BE SCH. 40 PVC.
2. ALL AAV (AIR ADMITTANCE VENT) VALVES TO BE ACCESSIBLE IN CABINETS OR BY ACCESS GRILLE FOR MAINTENANCE.
3. ALL WORK TO BE INSPECTED AND TESTED IN ACCORDANCE WITH LOCAL CODES.

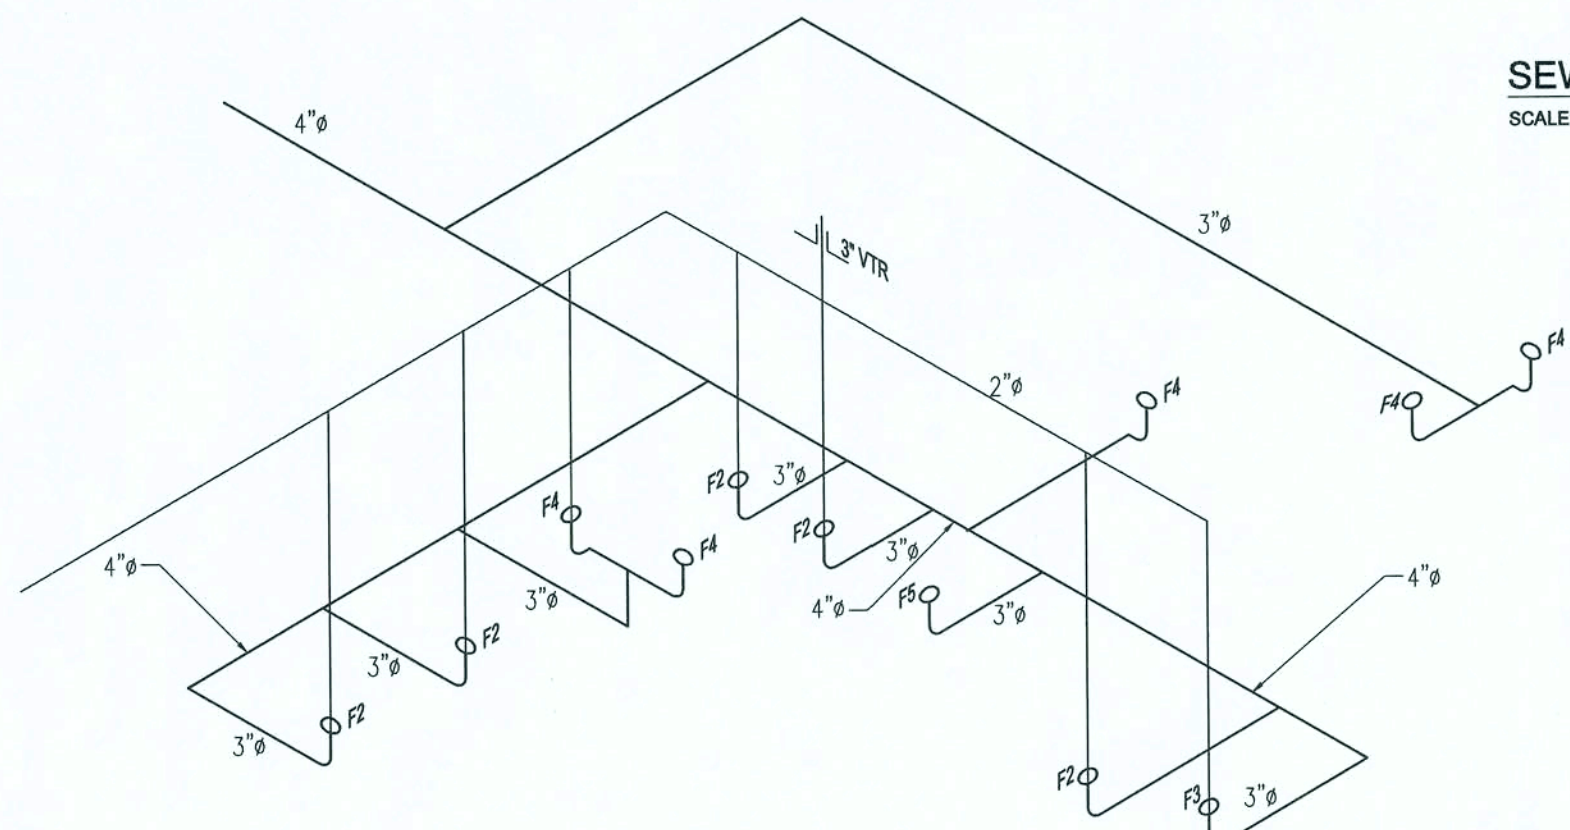

SEWER PLAN
SCALE: 1/8" = 1'-0"

1. DRAWINGS ARE DIAGRAMMATIC AND SHALL NOT BE SCALED; REFER TO ARCHITECTURAL PLANS AND ELEVATIONS FOR EXACT LOCATION OF ALL PLUMBING FIXTURES, EQUIPMENT, ETC. PLUMBING CONTRACTOR SHALL FURNISH AND INSTALL ALL ITEMS REQUIRED FOR A COMPLETE AND ACCEPTABLE WORKING INSTALLATION.
2. ALL WORK AND MATERIAL SHALL COMPLY WITH THE NATIONAL, STATE, AND ALL LOCAL CODES AND ORDINANCES HAVING JURISDICTION.
3. THE PLUMBING CONTRACTOR SHALL VISIT THE SITE AND THOROUGHLY FAMILIARIZE HIMSELF WITH ALL EXISTING CONDITIONS. ALL EXECUTION AND BACKFILL AS REQUIRED FOR THIS PHASE OF CONSTRUCTION SHALL BE A PART OF THIS CONTRACT.
4. ALL MATERIAL SHALL BE NEW.
5. ALL WORK SHALL BE PERFORMED BY A LICENSED PLUMBING CONTRACTOR IN A FIRST CLASS WORKMANLIKE MANNER. THE COMPLETED SYSTEM SHALL BE FULLY OPERATIVE AND ACCEPTED BY ENGINEER/ARCHITECT.
6. ALL REQUIRED INSURANCE SHALL BE PROVIDED FOR PROTECTION AGAINST PUBLIC LIABILITY OR PROPERTY DAMAGE FOR THE DURATION OF THE WORK.
7. THE PLUMBING CONTRACTOR SHALL SECURE AND PAY ALL PERMIT FEES, INSPECTIONS, AND TESTS.
8. ALL WORK SHALL BE COORDINATED WITH OTHER TRADES TO AVOID INTERFERENCE WITH THE PROGRESS OF CONSTRUCTION. THE PLUMBING CONTRACTOR SHALL GUARANTEE ALL MATERIAL AND WORKMANSHIP FREE FROM DEFECTS FOR A PERIOD OF NOT LESS THAN (1) ONE YEAR FROM DATE OF ACCEPTANCE. CORRECTION OF ANY DEFECTS SHALL BE COMPLETED WITHOUT ADDITIONAL CHARGES AND SHALL INCLUDE REPLACEMENT OR REPAIR OF ANY OTHER PHASE IN THE INSTALLATION WHICH MAY HAVE BEEN DAMAGED THEREBY.
9. VERIFY LOCATION, SIZE AND INVERTS OF ALL EXISTING UTILITIES PRIOR TO START OF CONSTRUCTION. ADVISE ENGINEER/ARCHITECT OF ANY DISCREPANCIES.
10. ALL FIXTURES SHALL BE PROVIDED WITH READILY ACCESSIBLE STOPS.
11. WATER PIPING SHALL BE CPVC.
12. SOIL, WASTE, AND VENT PIPING SHALL BE PVC SCHEDULE 40. WASTE AND VENT PIPING ABOVE SLAB SHALL BE PVC.
13. AIR CONDITIONING CONDENSATE DRAIN PIPING SHALL BE PVC SCHEDULE 40. INSULATE ALL CONDENSATE PIPING EXCEPT EXTERNAL PIPING. ALL PIPING TO BE INSTALLED PER LOCAL CODE.
14. FURNISH AND INSTALL APPROVED AIR CHAMBERS AT EACH PLUMBING FIXTURE AND PDI APPROVED SHOCK ARRESTERS ON MAIN LINE AND RISERS.
15. PROVIDE CHROME PLATED COMBINATION COVERED PLATE AND CLEANOUT PLUG FOR ALL WALL CLEANOUTS, JOSAM #58890.
16. INSULATE LINES AS FOLLOWS:
a. WATER SUPPLY AND RETURNS: 1" THICK ARMAFLEX
b. CONDENSATE DRAIN: 1/2" THICK ARMAFLEX

WATER HEATER
SHALL BE OF ELECTRIC TYPE. (PER OWNER)

WC
SHALL BE AN AMERICAN STANDARD MODEL NEW CADET II AQUAMETER 2174/138 ELONGATED TANK 1.8 GPF, VITREOUS CHINA, SIPHON ACTION BOWL, CLOSE-COUPLED TANK, SPEED CONNECT TANK/BOWL COUPLING SYSTEM TOILET AND AN OLSONITE #66 OPEN SEAT LESS COVER.

HC WC
SHALL BE AN AMERICAN STANDARD MODEL NEW CADET II AQUAMETER 2216, 43 ELONGATED 18" HIGH, 1.6 GPF, VITREOUS CHINA, SIPHON ACTION BOWL, CLOSE-COUPLED TANK, SPEED CONNECT TANK/BOWL COUPLING SYSTEM TOILET AND AN OLSONITE #66 OPEN SEAT LESS COVER.

KITCHEN SINK
SHALL BE ELKAY LUSTERTONE MODEL DLH-2222-10-C SINGLE BOWL, STAINLESS STEEL, SELF-RIMMING SINK WITH LK2432 HI-ARC FAUCET TO INCLUDE AN OMNI PRESSURE COMPENSATING 2.0 GPM FLOW RESTRICTOR.

JANITOR SINK
SHALL BE AN AMERICAN STANDARD MODEL FLORWELL 7740.020 ENAMELED CAST IRON SERVICE SINK WITH 7745.011 REMOVABLE VINYL-COATED RIM GUARD, 7721.038 DRAIN WITH STRAINER AND 7288.152 HERITAGE SERVICE SINK FITTING FAUCET TO INCLUDE AN OMNI PRESSURE COMPENSATING VANDAL RESISTANT 2.0 GPM FLOW RESTRICTOR WITH BUCKET HOOKS.

LAV
SHALL BE AN AMERICAN STANDARD MODEL RONDALYN 0491.019 VITREOUS CHINA SELF-RIMMING STYLE CLASSIC ROUND SHAPE, PROVIDE A 5401.172H HERITAGE CENTER SET FAUCET TO INCLUDE AN OMNI PRESSURE COMPENSATING 0.5 GPM FLOW RESTRICTOR.

HC LAV
SHALL BE AN AMERICAN STANDARD MODEL RONDALYN 0491.019 VITREOUS CHINA SELF-RIMMING STYLE CLASSIC ROUND SHAPE, PROVIDE A 5401.172H HERITAGE CENTER SET FAUCET WITH 4" WRIST BLADE HANDLES TO INCLUDE AN OMNI PRESSURE COMPENSATING 0.5 GPM FLOW RESTRICTOR. AQUASEAL VALVE AND CHROME FINISH, GRIP DRAIN, OFFSET PERFORATED ARM/ELBOW, LAVATORY DRAIN ASSEMBLY WITH 1-1/2" TAILPIECE, MCGUIRE #195WC.

EWC
SHALL BE AN OASIS MODEL PLF#WME, 8.0 GPM, 4.8 FLA AT 120 VOLT WITH 1/2 HP COMPRESSOR HOSE BIBB

SHALL BE A JOSAM 71000-95 SERIES CAST BRONZE BOX TYPE NON-FREEZE VANDAL PROOF WALL HYDRANT WITH COVER AND CONTROL KEY.

- NOTES:
1. ALL PLUMBING FIXTURES SHALL BE AS SPECIFIED OR APPROVED EGTAL.
 2. PROVIDE ANGLE STOPS ON ALL WATER SERVICE LINES TO FIXTURE FOR INDIVIDUAL SHUT-OFF.
 3. ALL HANDICAP PLUMBING FIXTURES SHALL BE INSTALLED PER THE LATEST ADA REQUIREMENTS.

P.O. Box 187
130 West Howard Street
Live Oak FL 32064
Phone: (386) 362-3678
Fax: (386) 362-6133
GARY GILL, PE 51942
Auth. # 9461



STRUCTURAL/CIVIL ENGINEERS

7TH DAY ADVENTIST CHURCH
NEW WORSHIP CENTER
COLUMBIA COUNTY, FLORIDA

PLUMBING PLAN

PROJECT NUMBER
PF06-193S

DRAWN BY

CHECKED BY

G.G.

P-2

SHEET 16 OF 16

ISSUED FOR APPROVAL

9/5/07