




6100 SE 68th Street, Ocala, FL 34472
 Phone (352) 347-7661 Fax: (347) 347-7797

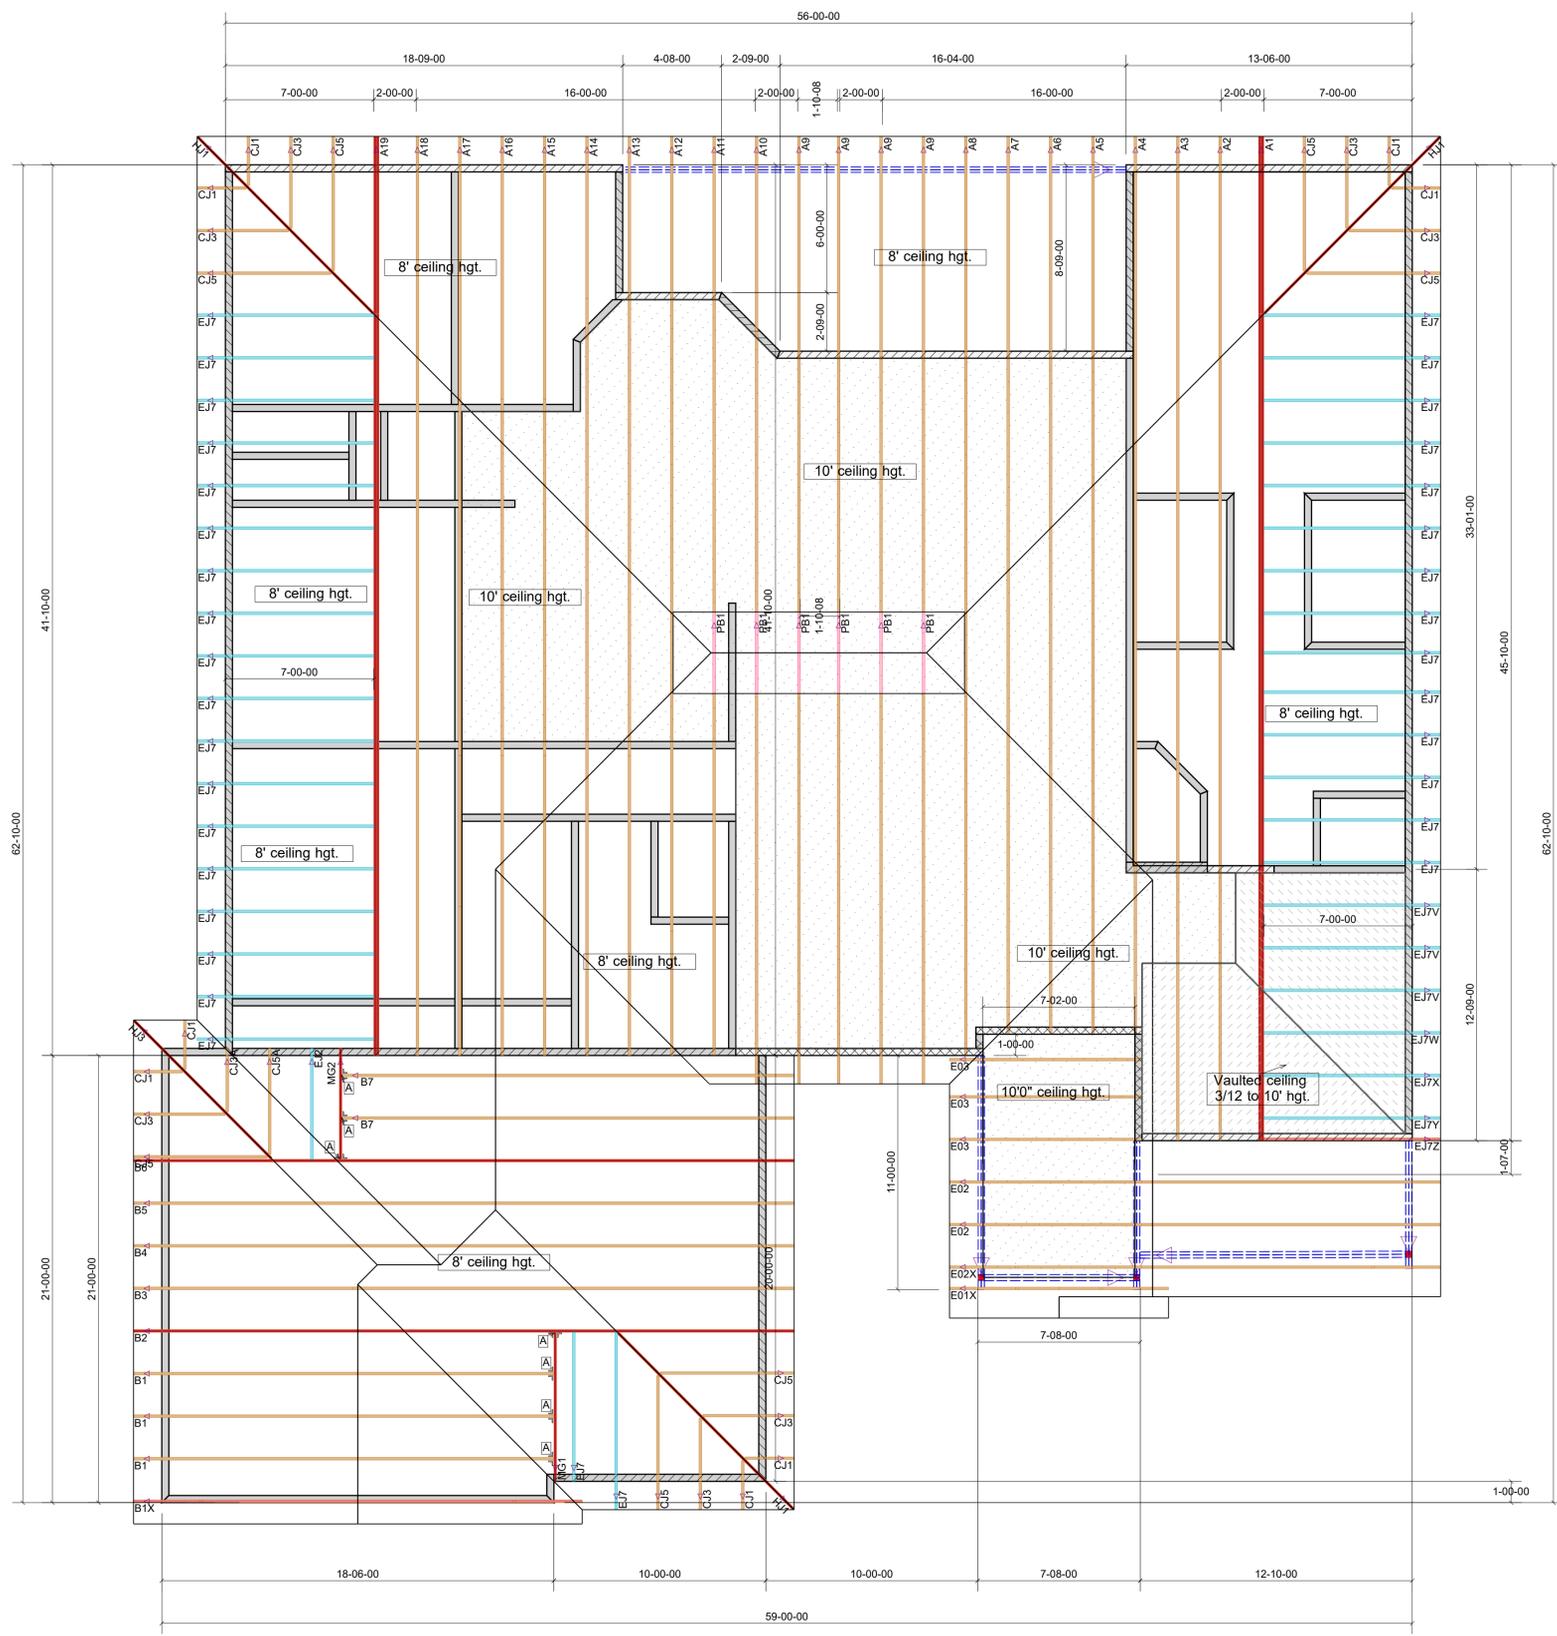

Hatch Legend	
	3/12 Vaulted Ceiling
	10'-0" Flat Ceiling
	8'1" bearing hgt.
	10'1" bearing hgt.

CLIENT APPROVAL

*** Signature of this document acknowledges that the client has reviewed this truss placement diagram in its entirety as in agreement with the following terms, including, but not limited to:

- The client is responsible to verify the accuracy of information submitted for use in design, fabrication and scheduling. Any labor, material or time delay incurred from inadequate or incorrect information supplied from the client, will be at the client's expense. Any field measurements by an associate of Tibbetts Lumber Co., LLC, are performed as a courtesy to the client and shall be verified by the client.
- Design Criteria: The client acknowledges that the truss design criteria noted on this truss placement diagram meets or exceeds the design criteria specified by the building designer, engineer of record, and local and state building requirements.
- Fabrication and Delivery: One approved truss placement diagram must be returned to the truss manufacturer before fabrication and delivery will be scheduled. It is the client's responsibility to coordinate delivery dates with the truss manufacturer. The client shall provide a marked location for delivery, which must be accessible, level and clear of materials and debris. In lieu of this, truss will be delivered in the best available location at our driver's discretion. Care and handling of the trusses following delivery is the responsibility of the client.
- Installation & Bracing: BCS 2008 (Building Component Safety Information) WCA/TP1 guidelines shall be followed when handling, installing & bracing trusses. Temporary and/or permanent bracing and blocking is not included in this truss package. Trusses shall be braced to prevent rotation and provide lateral stability in accordance with the requirements specified in the construction documents for the building and as the individual truss design drawings. The overall stability of the truss system is the responsibility of the building designer.
- Field Framing: 1) Truss ceilings and other ceiling transitions require field framing by others. 2) Ceiling drops and soffits not shown are to be field framed by others. 3) Overhangs may be overlength - cut as fit in the field. Overhangs are 24" or 24" - no blocking is applied. Corner jacks will be square cut and top jacks will be double level.
- Repairs: Truss related problems are to be reported to the truss manufacturer ASAP, preferably in writing. Do Not Cut Any Trusses before contacting the truss manufacturer with specifics of the problem. Any field modifications made without an engineered repair drawing will be the responsibility of the client. No back charges or crane charges of any kind will be accepted unless specifically approved in writing by the truss manufacturer's management.
- This Truss Placement Diagram was not created by an engineer, either by Tibbetts Lumber Co., LLC staff and is purely to be used as an installation guide and does not require a seal. Truss design analysis are on the Truss Design Drawings, which may be sealed by the Truss Design Engineer.

Floor: Load: 55# psf; 40 TCLL, 10 TC DL, 00 BCLL, 05 BCDL; Dur.: 1.00
 Design checked for 10 psf non-concurrent LL on BC.

Roof: Load: 40# psf; 20 TCLL, 10 TC DL, 00 BCLL, 10 BCDL; Dur.: 1.25
 Design checked for 10 psf non-concurrent LL on BC

TYPICAL DESIGN CRITERIA			
Mitek Engineering Building Code	: FBC 2023	Exposure	: B
	: ASCE 7-22	Mean Height	: ≤ 15'
	: TPI 1-2014	Bldg. Category	: II
Truss Design	: Comp. & Cladding	Importance Factor	: 1.00
Uplift Calculations	: MWFRS	Enclosure	: Enclosed
Wind Speed	: 130 mph US	Entry	: Exposed to Wind
		Lanai	: Exposed to Wind
ROOF CRITERIA		FLOOR CRITERIA	
T.C. Pitch	: 6/12	T.C. Size	: PC42
B.C. Pitch	: 3/12	Depth	: 16"
T.C. Size	: 2x4	Spacing	: 16" O.C.
Heel Height	: 4 3/16"	Bearing	: 8"
Bearing	: 4"	Lumber	: SP
Cantilever	: 0	Vapor barrier between floor & concrete by other.	
Overhang	: 16"	Floor trusses held back 3/4" at exterior wall,	
O.H. Cut	: Plumb	block and fill by other. Blocking for transfer of	
Spacing	: 24" O.C.	vertical load from above by others. Odd space	
Lumber	: SP	floor trusses around plumbing as noted.	

Roof Truss to Truss Connectors				Floor Truss to Truss Connectors			
A	TYP: THD26			*Z	TYP: THD46		
*a	JUS24	G	THDH28-2	M	HJC26	Q	THDH46
B	THD26-2	H	THDH28-3	N		R	THD48
C	THDH26-2	I	THDH210-3	O		S	THDH48
D	THDH26-3	J	GTWS2T			T	THDH410
E	THD28	K	GTWS3T			U	THDH610
F	THDH28	L	GTWS4T			V	MSH422

Installation shall be per connector manufacturer's guidelines. All connectors and tie downs other than truss to girder truss connectors are to be specified and supplied by others.

UP-LIFT SUMMARY			
1		11	21
2		12	22
3		13	23
4		14	24
5		15	25
6		16	26
7		17	27
8		18	28
9		19	29
10		20	30

Only points listed above have reactions > 5000# or Uplift > 1000#. Values shown on the sealed Truss Design Drawings supersede the above

NOTES	
N1	.
N2	.
N3	.
N4	.
N5	.
N6	.
N7	.
N8	.
N9	.

Diamond indicates left side of truss on truss design drawings

Client Info	
Client:	Adams Homes
Project:	Model :2265-C 3 Car FE
Address:	Lot # 32 The Preserve at Laurel Lake Lake City , Florida

*** Approved By: _____ Delivery Date: _____

Please Print Name _____ Employed By _____ Approval Date _____

Date	: 11/20/25	Scale	: 1/4" = 1'-0"	D=	1/4
Revised	: .	Drawn By	: Steve R.		
Sheet #	: 1 of 1	Job #	: 6252819		