

ARCHII ECI URAL DESIGN SOFTWAR

**REVISIONS** 

Erkinger Construction
Group

Kieth and Tammy Miller Residence

ADDRESS:
Lot #29
Indian Ridge
S/D
Columbia County, Fl

Mark Disosway P.E. P.O. Box 868 Lake City, Florida 32056 Phone: (386) 754 - 5419 Fax: (386) 269 - 4871

PRINTED DATE:
May 14, 2013
AWN BY: CHECKE

DRAWN BY: CHECKED BY: Matthew A. Erkinger Sr.

FINALS DATE: 2013-05-14

JOB NUMBER: 1304097

DRAWING NUMBER

OF 3 SHEETS

32'-6" 1.5'-5" 6'-5" COVERED PORCH CONCRETE OBSCURED FIXED
4'-0" x 2'-0" 8' WALL / TRUSS BEARING DINETTE VAULTED CEILING WALK-IN CLOSET 8' CEILING CATHEDIRAL CEILING 4 X 10 X 16" OPEN BEAMS SPACED@ 48" OC 8' CLG BATH 8' CEILING BEDROOM #2 8' CEILING FAMILY ROOM VAULTED CEILING MASTER BEDROOM 8' CEILING 8' WALL / TRUSS BEARING 3'-0" x 5'-0" 3'-0" x 5'-0" 3'-0" x 5'-0" 3'-0" x 5'-0" 5'-6" 3'-0" 5'-6" **COVERED PORCH** 2 X 10 OPEN TRUSSES AT ENTRY 8' CEILING **COVERED PORCH** 8' CEILING 15'-6" 8'-0" 50'-(0" 8'-0" NOTE: STORAGE TRUSSES ABOVE LEFT SIDE OF CATHEDRAL CEILING NOTE: STORAGE TRUSSES ABOVE RIGHT SIDE OF CATHEDRAL CEILING FLOOR PLAN SCALE: 1/4" = 1'-0" AREA SUMMARY LIVING AREA 1,520 S.F. PORCH AREA 896 S.F. **TOTAL AREA** 2,313 S.F.

REVISIONS

SOFTPIX
ARCHITECTURAL DESIGN SOFTW

Erkinger Construction
Group

Kieth and Tammy Miller
Residence

ADDRESS:
Lot #29
Indian Ridge
S/D
Columbia County, Fl

Mark Disosway P.E. P.O. Box 868 Lake City, Florida 32056 Phone: (386) 754 - 5419 Fax: (386) 269 - 4871

PRINTED DATE:
May 14, 2013

DRAWN BY: CHECKED BY:

Matthew A. Erkinger Sr.

FINALS DATE: 2013-05-14

JOB NUMBER: 1304097

> #2 OF 3 SHEETS

DRAWING NUMBER


**REVISIONS** 

## **ELECTRICAL PLAN NOTES**

- E -1 WIRE ALL APPLIANCES, HVAC UNITS AND OTHER EQUIPMENT PER MANUF. SPECIFICATIONS.
- E -2 CONSULT THE OWNER FOR THE NUMBER OF SEPERATE TELEPHONE LINES TO BE INSTALLED.
- E -3 ALL INSTALLATIONS SHALL BE PER NAT'L. ELECTRIC CODE.
- E -4

  ALL SMOKE DETECTORS SHALL BE 120V W/ BATTERY
  BACKUP OF THE PHOTOELECTRIC TYPE, AND SHALL
  BE INTERLOCKED TOGETHER. INSTALL INSIDE AND
  NEAR ALL BEDROOMS.
- E -5
  TELEPHONE, TELEVISION AND OTHER LOW VOLTAGE
  DEVICES OR OUTLETS SHALL BE AS PER THE OWNER'S
  DIRECTIONS, & IN ACCORDANCE W/ APPLICABLE
  SECTIONS OF NEC-LATEST EDITION.
- E -6 ELECTRICAL CONT'R SHALL BE RESPONSIBLE FOR THE DESIGN & SIZING OF ELECTRICAL SERVICE AND CIRCUITS.
- E -7 ENTRY OF SERVICE ( UNDERGROUND OR OVERHEAD )
  TO BE DETERMINED BY POWER COMPANY.
- E -8 ALL BEDROOM RECEPTACLES SHALL BE AFCI
- E -9 ALL OUTLETS TO BE LOCATED ABOVE BASE FLOOD ELEVATION
- A SERVICE DISCONNECT WITH OVER CURRENT PROTECTION SHALL BE INSTALLED OUTSIDE OF THE BUILDING, ON THE LOAD SIDE OF THE METER, AT THE PLACE ELECTRIC CONDUCTORS ENTER THE BUILDING.
- SERVICE ENTRANCE CONDUCTORS MAY NOT BE LOCATED INSIDE OF THE OF THE BUILDING WITHOUT SPECIAL APPROVAL OF THE BUILDING OFFICIAL

0	ELECTRICAL LEGENT
	CEILING FAN (PRE-WIRE FOR LIGHT KIT)
90	DOUBLE SECURITY LIGHT
	2X4 FLUORESCENT LIGHT FIXTURE
0	RECESSED CAN LIGHT
	BATH EXAUST FAN WITH LIGHT
₩	BATH EXAUST FAN
	LIGHT FIXTURE
Ф	DUPLEX OUTLET
•	220v OUTLET
<b>⊕</b> GFI	GFI DUPLEX OUTLET
•	SMOKE DETECTOR
\$	WALL SWITCH
\$3	3 WAY WALL SWITCH
\$4	4 WAY WALL SWITCH
₩P/GFI	WATER PROOF GFI OUTLET
$\nabla$	PHONE JACK
0	TELEVISION JACK
•	GARAGE DOOR OPENER
	WALL HEATER

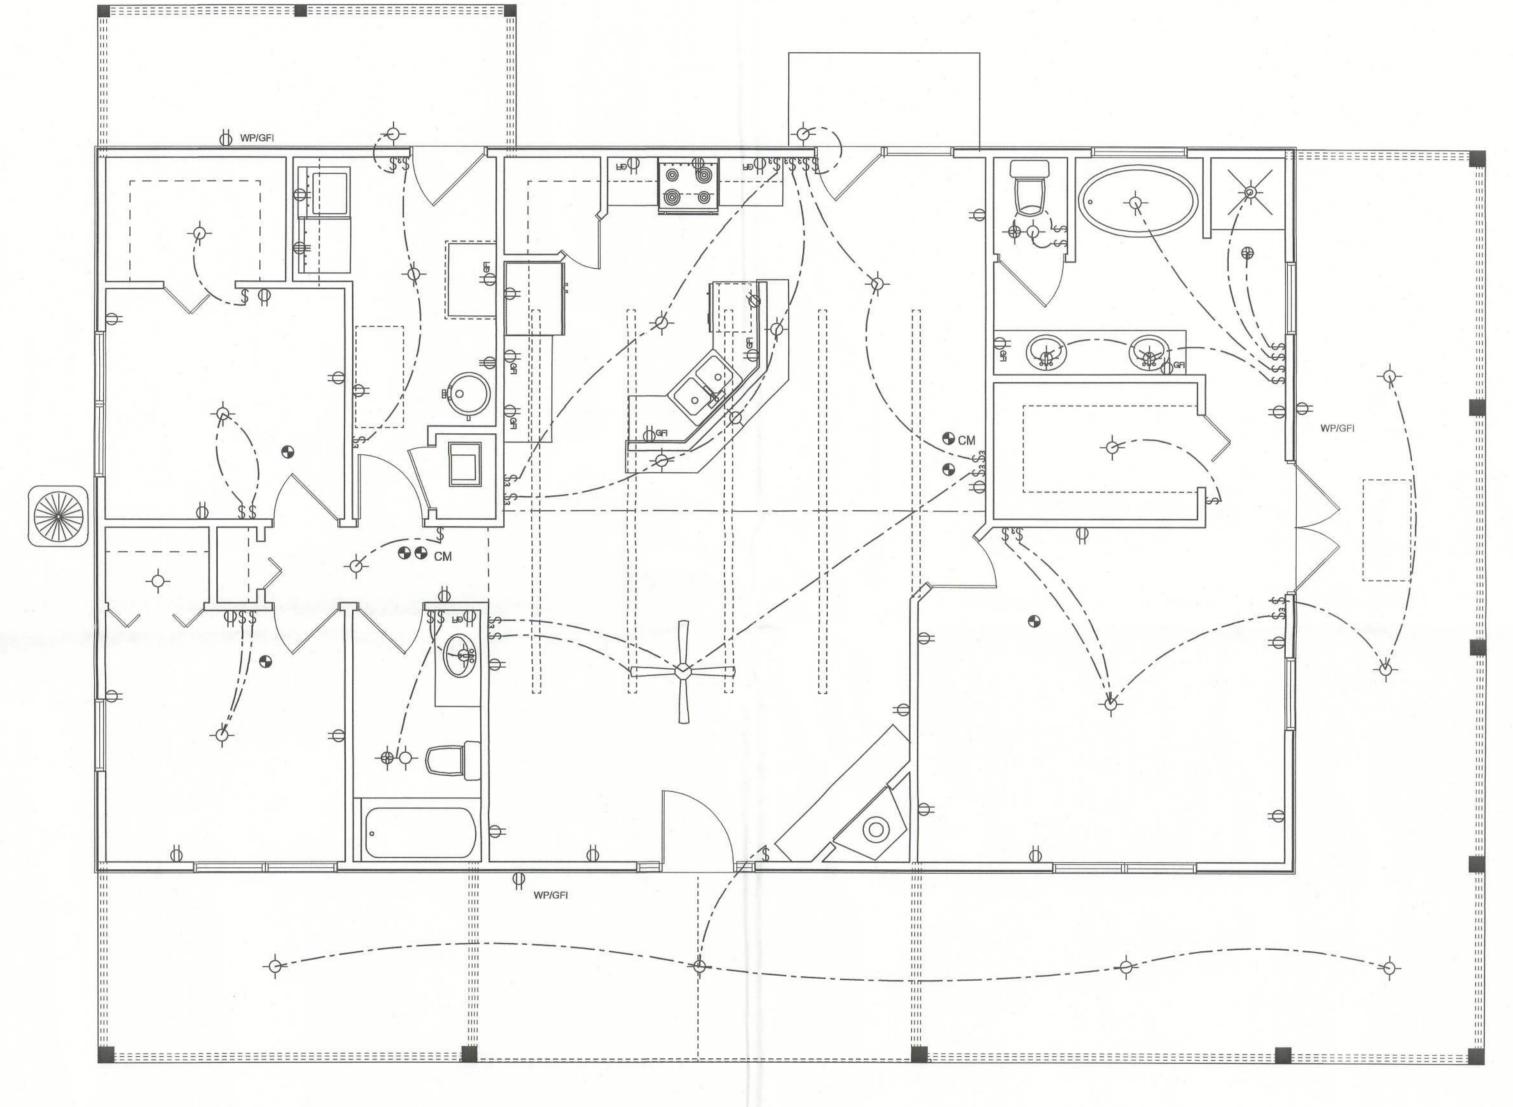

ELECTRICAL PLAN
SCALE: 1/4" = 1'-0"

**Erkinger Construction** Group

Kieth and Tammy Miller Residence ADDRESS: Lot #29 Indian Ridge

Mark Disosway P.E. P.O. Box 868 Lake City, Florida 32056 Phone: (386) 754 - 5419 Fax: (386) 269 - 4871

Columbia County, Fl

PRINTED DATE: May 14, 2013 DRAWN BY: CHECKED BY: Matthew A. Erkinger Sr.

FINALS DATE: 2013-05-14

JOB NUMBER: 1304097 DRAWING NUMBER

OF 3 SHEETS

