

# MAIN FLOOR

SCALE: 0.0938" = 1'-0"


DESCRIPTION	QUANTITY	SYMBOL
can light	1	○
Chandelier	1	⊙
42" ceiling fan	1	⊗
Exterior ceiling fan	2	⊗
Interior 52" ceiling fan	4	⊗
Flush mount ceiling lights	13	○
Pendants	2	○
12in flush mount ceiling lights combination fan and light-round electrical panel	1	⊗
exterior craftsman light fixture	4	⊗
fluorescent light 1 x 4	2	⊗
spotlight double with motion detector	1	⊗
vanity bar light 02	1	⊗

Area	SQ FT
Total Square Feet	2932 sq ft
Porches SF	618 sq ft
Heated SF	1809 sq ft
Garage SF	549 sq ft

John Norris Construction, LLC  
 Flouion Residence  
 Columbia County, FL


# MAIN FLOOR - ELECTRICAL

SCALE: 1/8" = 1'-0"

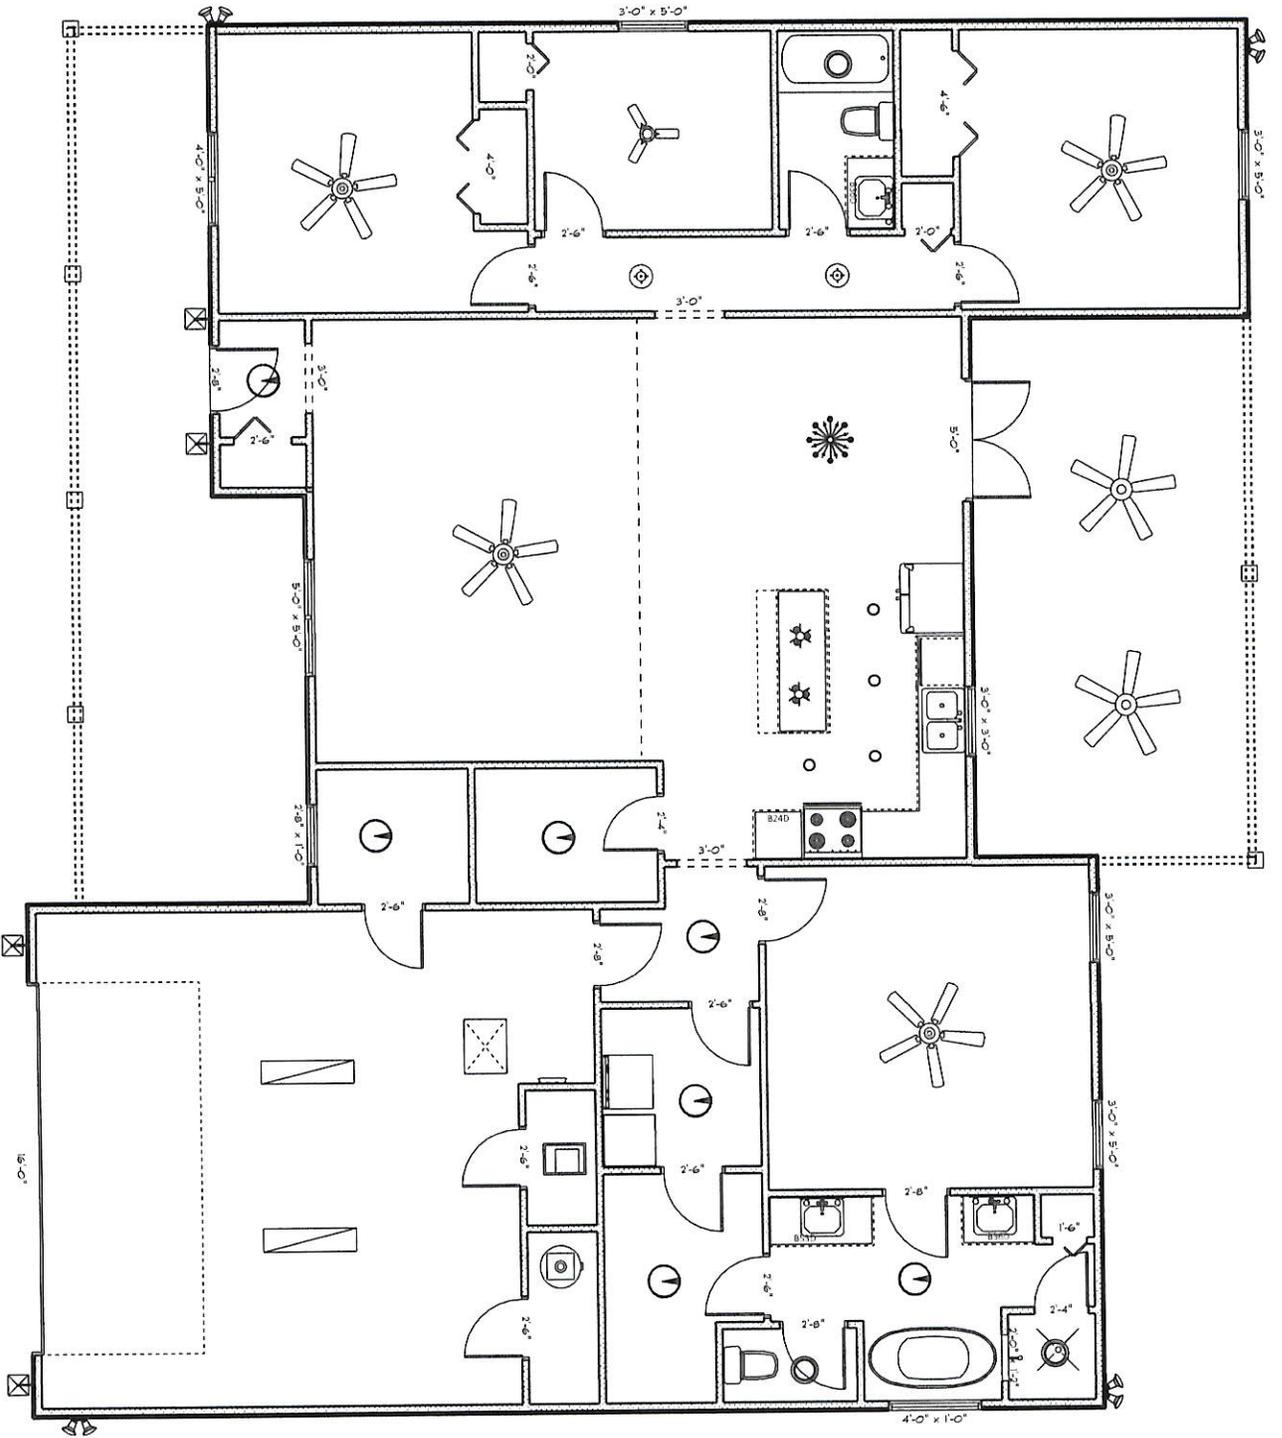


ELECTRICAL LEGEND		
DESCRIPTION	COUNT	SYMBOL
can light ginch	4	○
Chandelier	1	⊙
42" ceiling fan	1	⊙
Exterior ceiling fan	2	⊙
Interior 52" ceiling fan	4	⊙
Flush mount ceiling lights	10	⊙
Pendants	2	⊙
12in flush mount ceiling lights	2	⊙
combination fan and light-round	3	⊙
electrical panel	1	⊙
exterior craftsman light fixture	4	⊙
fluorescent light 1 x 4	2	⊙
spotlight double with motion detector	5	⊙
vanity bar light 02	3	⊙

AREA SCHEDULE		
Area	SQ FT	
Total Square Feet	2932 sq ft.	
Porches SF	618 sq ft.	
Heated SF	1809 sq ft.	
Garage SF	548 sq ft.	

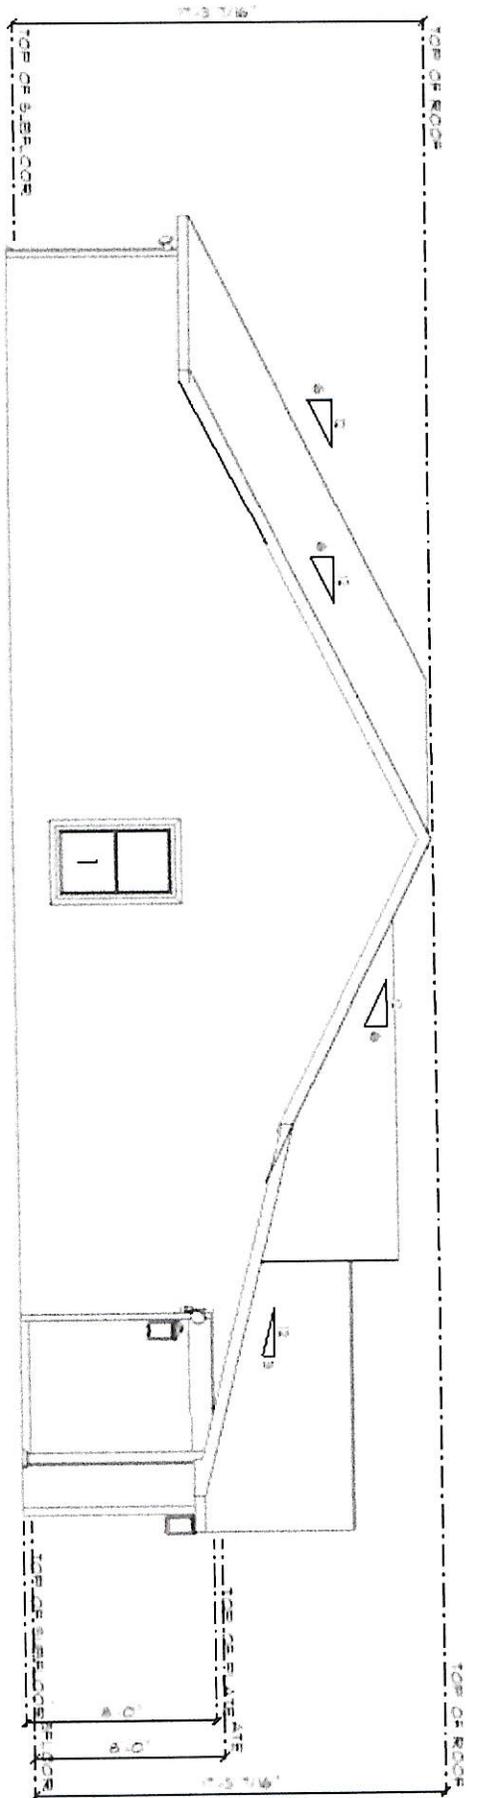


# WEST ELEVATION

SCALE: 0.1406" = 1'-0"

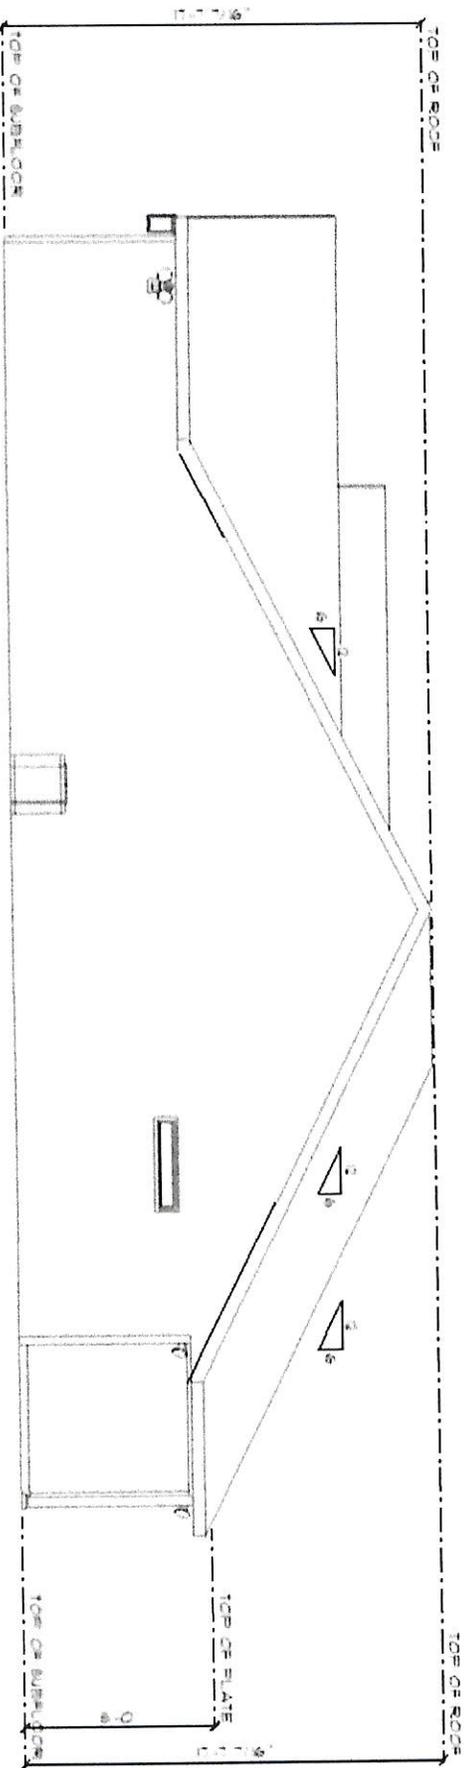


# EAST ELEVATION

SCALE: 0.1406" = 1'-0"

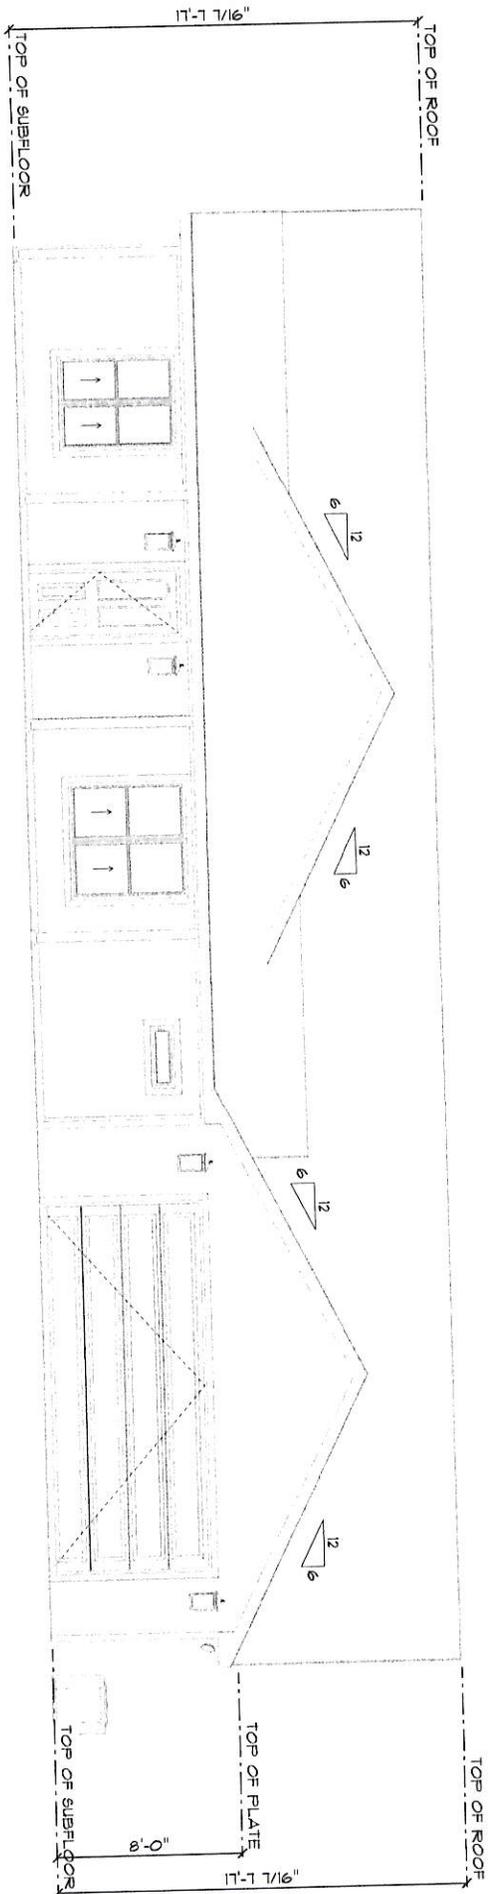

# SOUTH ELEVATION

SCALE: 1/8" = 1'-0"

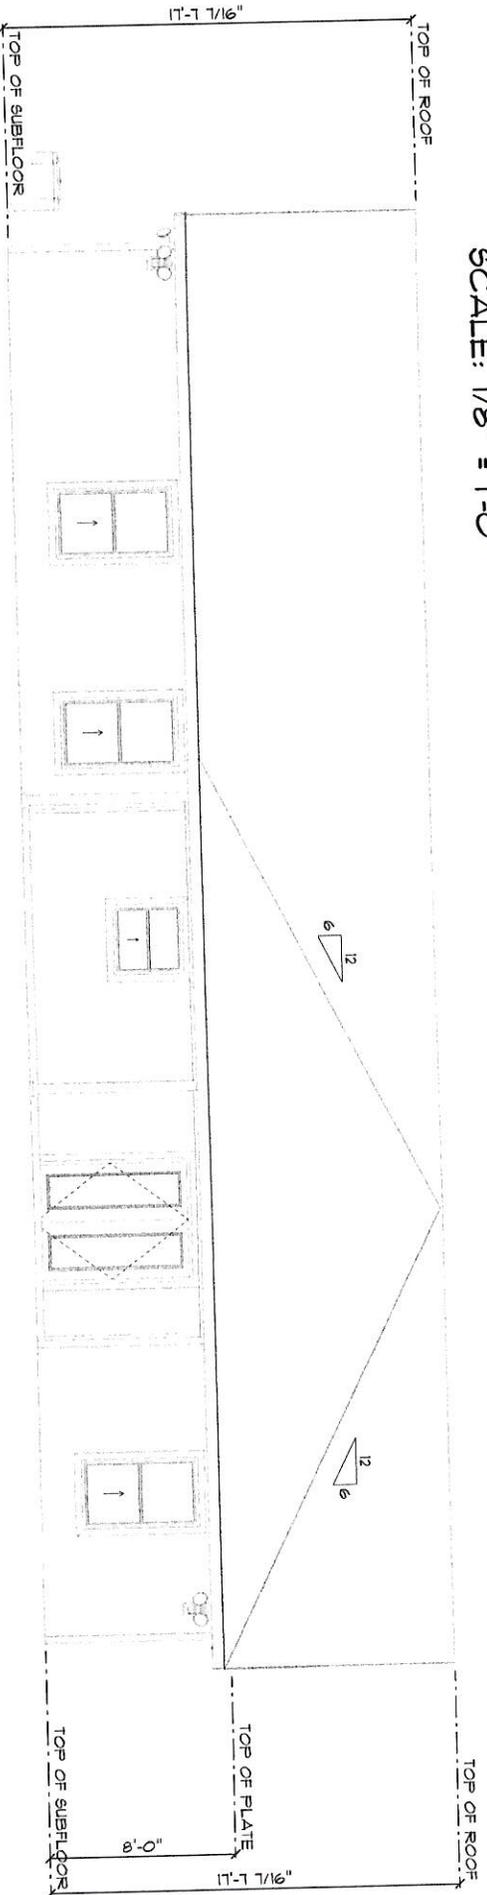

# NORTH ELEVATION

SCALE: 1/8" = 1'-0"