
ELECTRICAL LEGEND

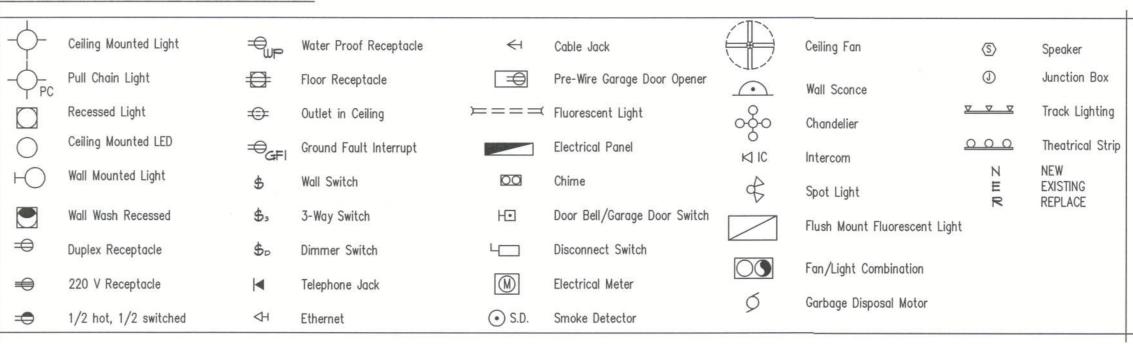

NOTES:

N N (M)

N 42"

I. ALL SMOKE DETECTORS ARE TO BE HARD WIRED AND INTERCONNECTED. 2. PROVIDE ARC FAULT PROTECTION IN ALL LIVING SPACES, EXCEPT IN BATHROOMS, KITCHEN, LAUNDRY, AND GARAGES. 3. USE COMBINATION SMOKE AND CARBON MONOXIDE ALARMS, OR PROVIDE A CARBON MONOXIDE ALARM (IN ADDITION TO SMOKE) WITHIN 10' OF EACH ROOM USED FOR SLEEPING PURPOSES (SEE FBCR 2010, SEC. R315) 4. EXACT LOCATIONS OF FIXTURES AND/OR OUTLETS ARE SUGGESTED AND MEET MOST LOCAL CODE REQUIREMENTS. ADDITIONS OR ADJUSTMENTS MAY BE MADE BETWEEN OWNER AND BUILDER IN THE FIELD.

revisions

Z

PLANNING ITIONS, RE

ШΩ

UD

44

ហ ហ

s, L

ZO

DESIGI BUILD

LSTOI ENAN

--

job no PARRISH drawn by DA checked DA date 08/03/22 scale AS NOTED drawing no.

A Proposed Right Elevation SCALE:1/4"=1'-0"

S.D. COMBO