

30925

PROPOSED RESIDENCE DENNILLE AND A.J. DECKER

468 NW HACKNEY TERRACE, LAKE CITY, FL 32055

PARCEL NUMBER
36-3S-16-02600-000 - COLUMBIA COUNTY, FLORIDA

SCOPE OF WORK
THIS PROJECT ENTAILS THE CONSTRUCTION OF A TWO-STORY RESIDENTIAL STRUCTURE, INCLUDING ALL REQUISITE ELECTRICAL WORK, CENTRAL AIR CONDITIONING, PLUMBING AND FIXTURES. CEILING FINISHES WILL BE GYPSUM WALLBOARD WITH TEXTURE. EXTERIOR WALL FINISHES WILL BE FACE BRICK AND CEMENT-BOARD SIDING. INTERIOR WALL FINISHES WILL BE GYPSUM WALLBOARD. ROOFING WILL BE FIBERGLASS ASPHALT SHINGLES. FLOORING AND TRIM SHALL BE PER OWNER'S SPECIFICATION.

ENGINEER'S STATEMENT
THIS PROJECT HAS BEEN DESIGNED IN ACCORDANCE WITH 2010 FLORIDA BUILDING CODE, RESIDENTIAL EDITION, SEC. R301 CRITERIA AND ASCE 7-10. TO THE BEST OF MY KNOWLEDGE THESE CONTRACT DOCUMENTS PREPARED UNDER MY DIRECT SUPERVISION COMPLY WITH THE APPLICABLE MINIMUM CODE REQUIREMENTS AND THE SAFETY STANDARDS AS DETERMINED BY THE LOCAL AUTHORITY IN ACCORDANCE WITH CHAPTERS 553 AND 553 OF THE FLORIDA STATUTES.

DISCLAIMER
THE EXISTING CONDITIONS AS SHOWN ON THIS SITE PLAN AND OTHER DRAWINGS AND DETAILS IN THIS PLAN SET ARE FROM SURVEY PLATS AND VERIFIED BY FIELD MEASUREMENTS. THE ENGINEER OF RECORD TAKES NO RESPONSIBILITY AS TO THE ACCURACY OR COMPLETENESS OF THE REPRESENTATIONS.

DESIGN CRITERIA	LIVE LOADS
CONSTRUCTION TYPE: V-B	ROOF = 20 PSF
WIND SPEED = 120 MPH (3 SEC. GUST)	FLOORS, STAIRS = 40 PSF
RISK CATEGORY = II	ATTIC, UNINHABITABLE, WITHOUT STORAGE = 10 PSF
WIND EXPOSURE = C	WITH STORAGE = 20 PSF
INTERNAL PRESSURE COEFF. = 0.18	

DESIGN WIND PRESSURES
(COMPONENTS AND CLADDING) - 120 MPH
0-10 SF = +30.4/-33.0
10-20 SF = +24.7/-26.9
20-50 SF = +23.2/-25.4
50-100 SF = +22.0/-24.2
100-500 SF = +19.3/-21.5

WALL SHEATHING FASTENING SCHEDULE
* USE 15/32" CDX OR 7/16" OSB SHEATHING (WOOD STRUCTURAL PANEL = W.S.P.)
* STANDARD EXTERIOR WALL: USE MIN. 8d HAND DRIVEN OR GUN NAILS SPACED AT EDGES AT 6" O.C. AND INTERIOR FIELD AT 12" O.C.
* EXTERIOR SHEARWALLS: USE MIN. 8d RING-SHANK GUN NAILS AT 4" O.C. ON EDGES AND ENDS AND INTERIOR FIELD AT 6" O.C.

WEATHER PROTECTION:
A) ALL FRAMED CONSTRUCTION EXPOSED TO EXTERIOR TO HAVE A VAPOR BARRIER INSTALLED BEFORE WALL FINISH IS APPLIED.
B) ALL ROOF DECKS SHALL BE COVERED WITH APPROVED ROOF COVERINGS IN ACCORDANCE WITH CURRENT FLORIDA BUILDING CODE. ROOF ASSEMBLIES SHALL BE INSTALLED IN ACCORDANCE WITH THIS CODE AND THE APPROVED MANUFACTURER'S INSTALLATION INSTRUCTIONS SUCH THAT THE ROOF ASSEMBLY SHALL PROTECT THE BUILDING AND STRUCTURE.
C) FLASHING TO BE INSTALLED TO PREVENT MOISTURE FROM ENTERING THE WALLS AND ROOFS THROUGH COPINGS, THROUGH MOISTURE PERMEABLE MATERIALS, AND AT INTERSECTIONS WITH PARAPET WALLS OR OTHER PENETRATIONS THROUGH ALL ROOF PLANES. USE METAL FLASHING WITH GALV. G90 26 GA. STEEL AND INSTALL AT WALL AND ROOF THROUGH JOINTS IN COPINGS, THROUGH MOISTURE PERMEABLE MATERIALS, AND AT INTERSECTIONS, WHEREVER THERE IS A CHANGE IN SLOPE OR DIRECTION AND AROUND ALL ROOF OPENINGS. ALL METAL FLASHING SHALL BE CORROSION RESISTANT AND THICKNESS TO BE NOT LESS THAN DESCRIBED IN FLORIDA BUILDING CODE TABLE R903.2.1 FLASHING NOT REQUIRED AT HIP AND RIDGE JUNCTIONS.

AREA SUMMARY
MAIN FLOOR CONDITIONED AREA 2445 S.F. 05.20.13
UPPER FLOOR CONDITIONED AREA 1662 S.F.
TOTAL CONDITIONED AREA 4108 S.F. 05.20.13
GARAGE AND STORAGE AREA 899 S.F.
VERANDA AND GAZEBO AREA 821 S.F.
ENTRY AREA 131 S.F.
TOTAL NON-CONDITIONED AREA 1851 S.F.
TOTAL AREA 5959 S.F. 05.20.13

GENERAL FRAMING NOTES
* ALL LUMBER TO SOUTHERN YELLOW PINE No. 2 OR SPRUCE-PINE-FIR No. 2, MAXIMUM MOISTURE CONTENT OF 19 %. EXTERIOR LUMBER AND LUMBER IN CONTACT WITH CONCRETE TO BE PRESSURE-TREATED.
* EXTERIOR WINDOWS AND GLASS DOORS MUST MEET THE REQUIREMENTS OF R-613-1 OF THE FLORIDA RESIDENTIAL BUILDING CODE 2010 EDITION.
R-613-1 EXTERIOR WINDOWS AND GLASS DOORS
R-613.1.1 TESTING AND LABELING. EXTERIOR WINDOWS AND GLASS DOORS SHALL BE TESTED BY AN APPROVED INDEPENDENT TESTING LABORATORY AND BEAR AN AAMA OR WDMA OR OTHER APPROVED LABEL IDENTIFYING THE MANUFACTURER, PERFORMANCE CHARACTERISTICS, AND APPROVED PRODUCT EVALUATION ENTITY TO INDICATE COMPLIANCE WITH THE REQUIREMENTS OF THE FOLLOWING SPECIFICATION: WINDOWS - ANSI/AAMA/NWDDA 101/1S2 OR 1S2/NAFS OR AAMA/WDMA/CSA 101/1S2/A440 OR TAS202 (HVHZ) SHALL COMPLY WITH TAS 202 UTILIZING ASTM.

SHEET INDEX
A1 PROJECT DATA, GENERAL NOTES, DESIGN CRITERIA
A2 MAIN FLOOR PLAN
A3 UPPER FLOOR PLAN
A4 ROOF PLAN
A5 EXTERIOR ELEVATIONS
A6 EXTERIOR ELEVATIONS
E1 MAIN FLOOR ELECTRICAL PLAN
E2 UPPER FLOOR ELECTRICAL PLAN
S1 FOUNDATION PLAN
S2 FLOOR FRAMING PLAN, LOWER ROOF FRAMING PLAN
S3 UPPER ROOF FRAMING PLAN
S4 SECTIONS AND DETAILS
S5 SECTIONS AND DETAILS
S6 SECTIONS AND DETAILS

DATE	REMARKS
03.18.13	PERMIT SET
05.20.13	ENLARGE BEDROOM 1

Ken Ehlers P.E.# 18243

STRUCTURAL PLAN SERVICE INC.
10000 W. 11th Ave. Box 940128
Miami, FL 33174
Phone (407) 286-8155
Fax (407) 286-8155
Ken Ehlers P.E.# 18243
LICENSED PROFESSIONAL ENGINEER

PLANS PREPARED BY AND UNDER THE DIRECT SUPERVISION OF
STRUCTURAL PLAN SERVICE, INC.
AND KEN EHLERS, P.E.

PETER WOODS, RESIDENTIAL DESIGNER
8504 PECAN RD., OCALA, FL 34472
peter.woods@residentialplan.com
(352) 675-4884

PROPOSED RESIDENCE
DENNILLE AND A.J. DECKER
468 NW HACKNEY TERRACE, LAKE CITY, FL 32055
PARCEL NO. 36-3S-16-02600-000

SHEET NUMBER
A1
PROJECT NO. 130103

SITE PLAN BY OTHERS

DATE	REMARKS
03.18.13	PERMIT SET
05.05.13	ADD GO-BOLTS
05.20.13	ENLARGE BEDROOM 1

Ken Ehlers P.E. # 18243


STRUCTURAL PLAN SERVICE INC.
COA #27162
Post Office Box 540128
Fort Lauderdale, FL 33324-0128
Phone (407) 255-6155
Fax (407) 255-6141
Ken Ehlers P.E. # 18243
LICENSED PROFESSIONAL ENGINEER

PLANS PREPARED BY AND UNDER THE
DIRECT SUPERVISION OF
STRUCTURAL PLAN SERVICE INC.
AND KEN EHLERS, P.E.



PETER WOODS, RESIDENTIAL DESIGNER
1804 ROCK RD., COALA, FL 34472
peter.woods@residentialdesign.com
(352) 575-4884

PROPOSED RESIDENCE
DENNILLE AND A.J. DECKER
468 NW HACKNEY TERRACE, LAKE CITY, FL 32055
PARCEL NO. 36-3S-16-02600-000

SHEET NUMBER
A2
PROJECT NO. 130103

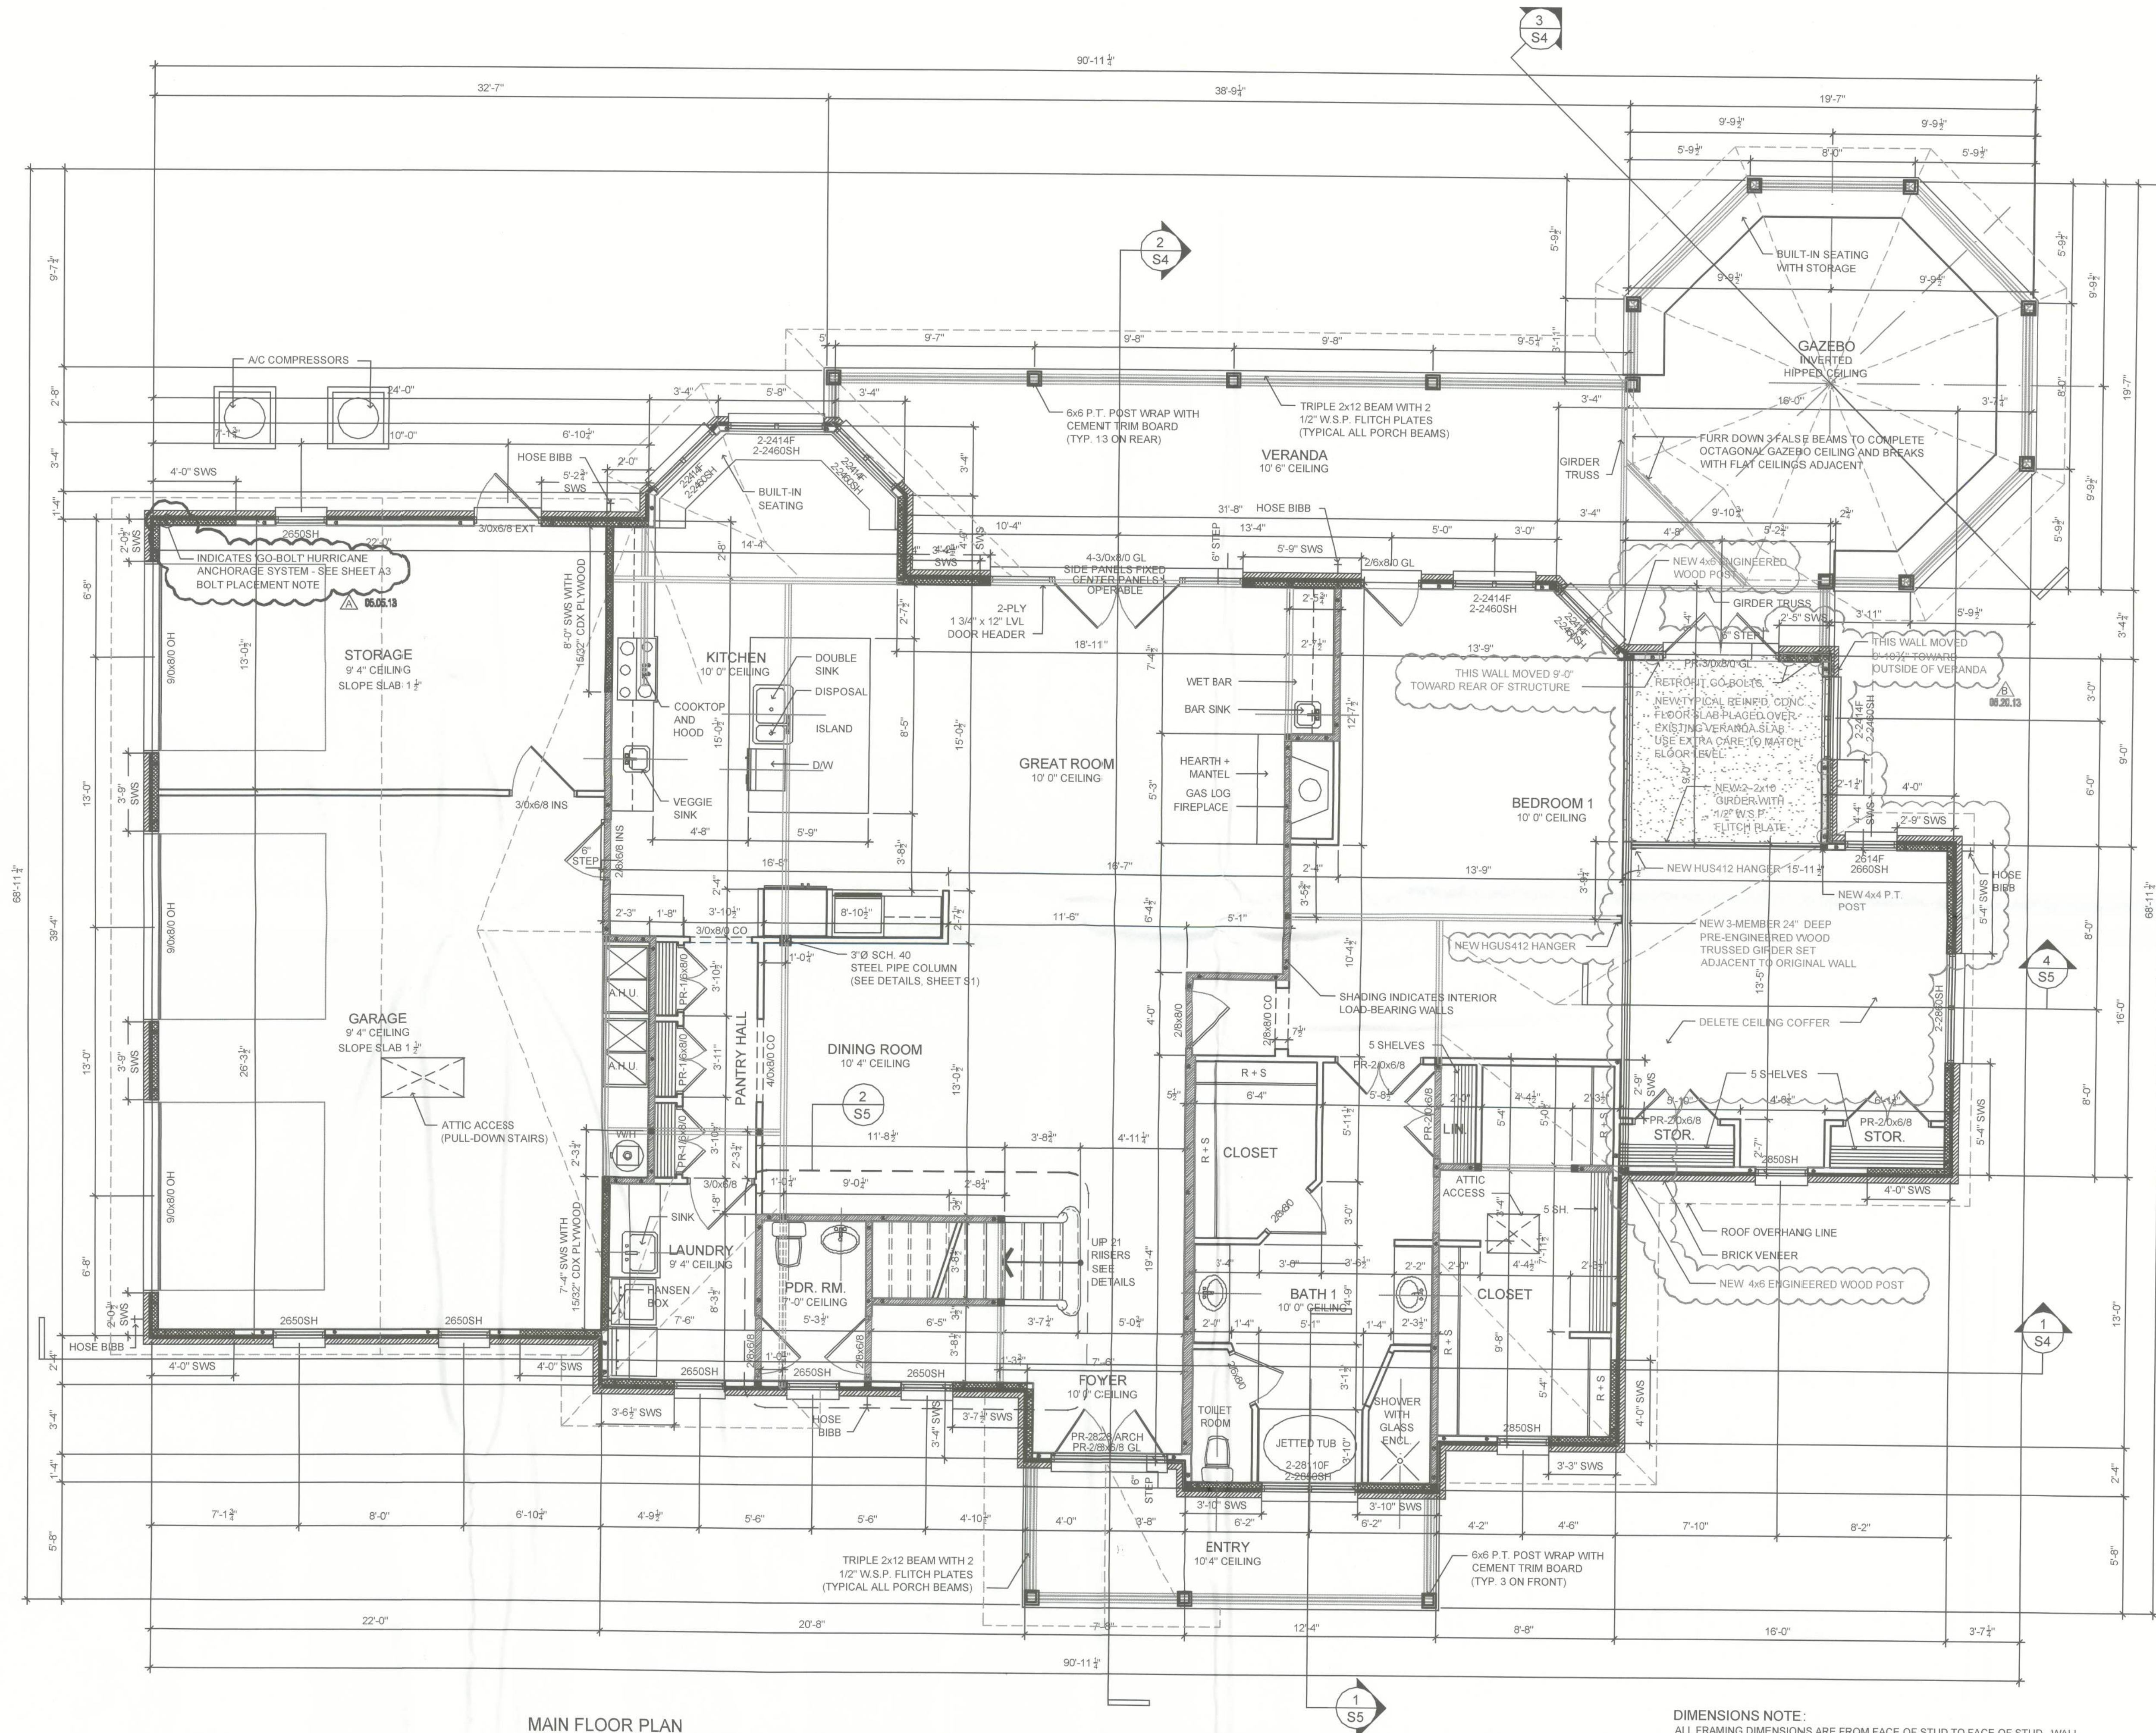

DIMENSIONS NOTE:
ALL FRAMING DIMENSIONS ARE FROM FACE OF STUD TO FACE OF STUD. WALL SHEATHING THICKNESS IS NOT INCLUDED IN DIMENSIONS, UNLESS SPECIFICALLY NOTED.

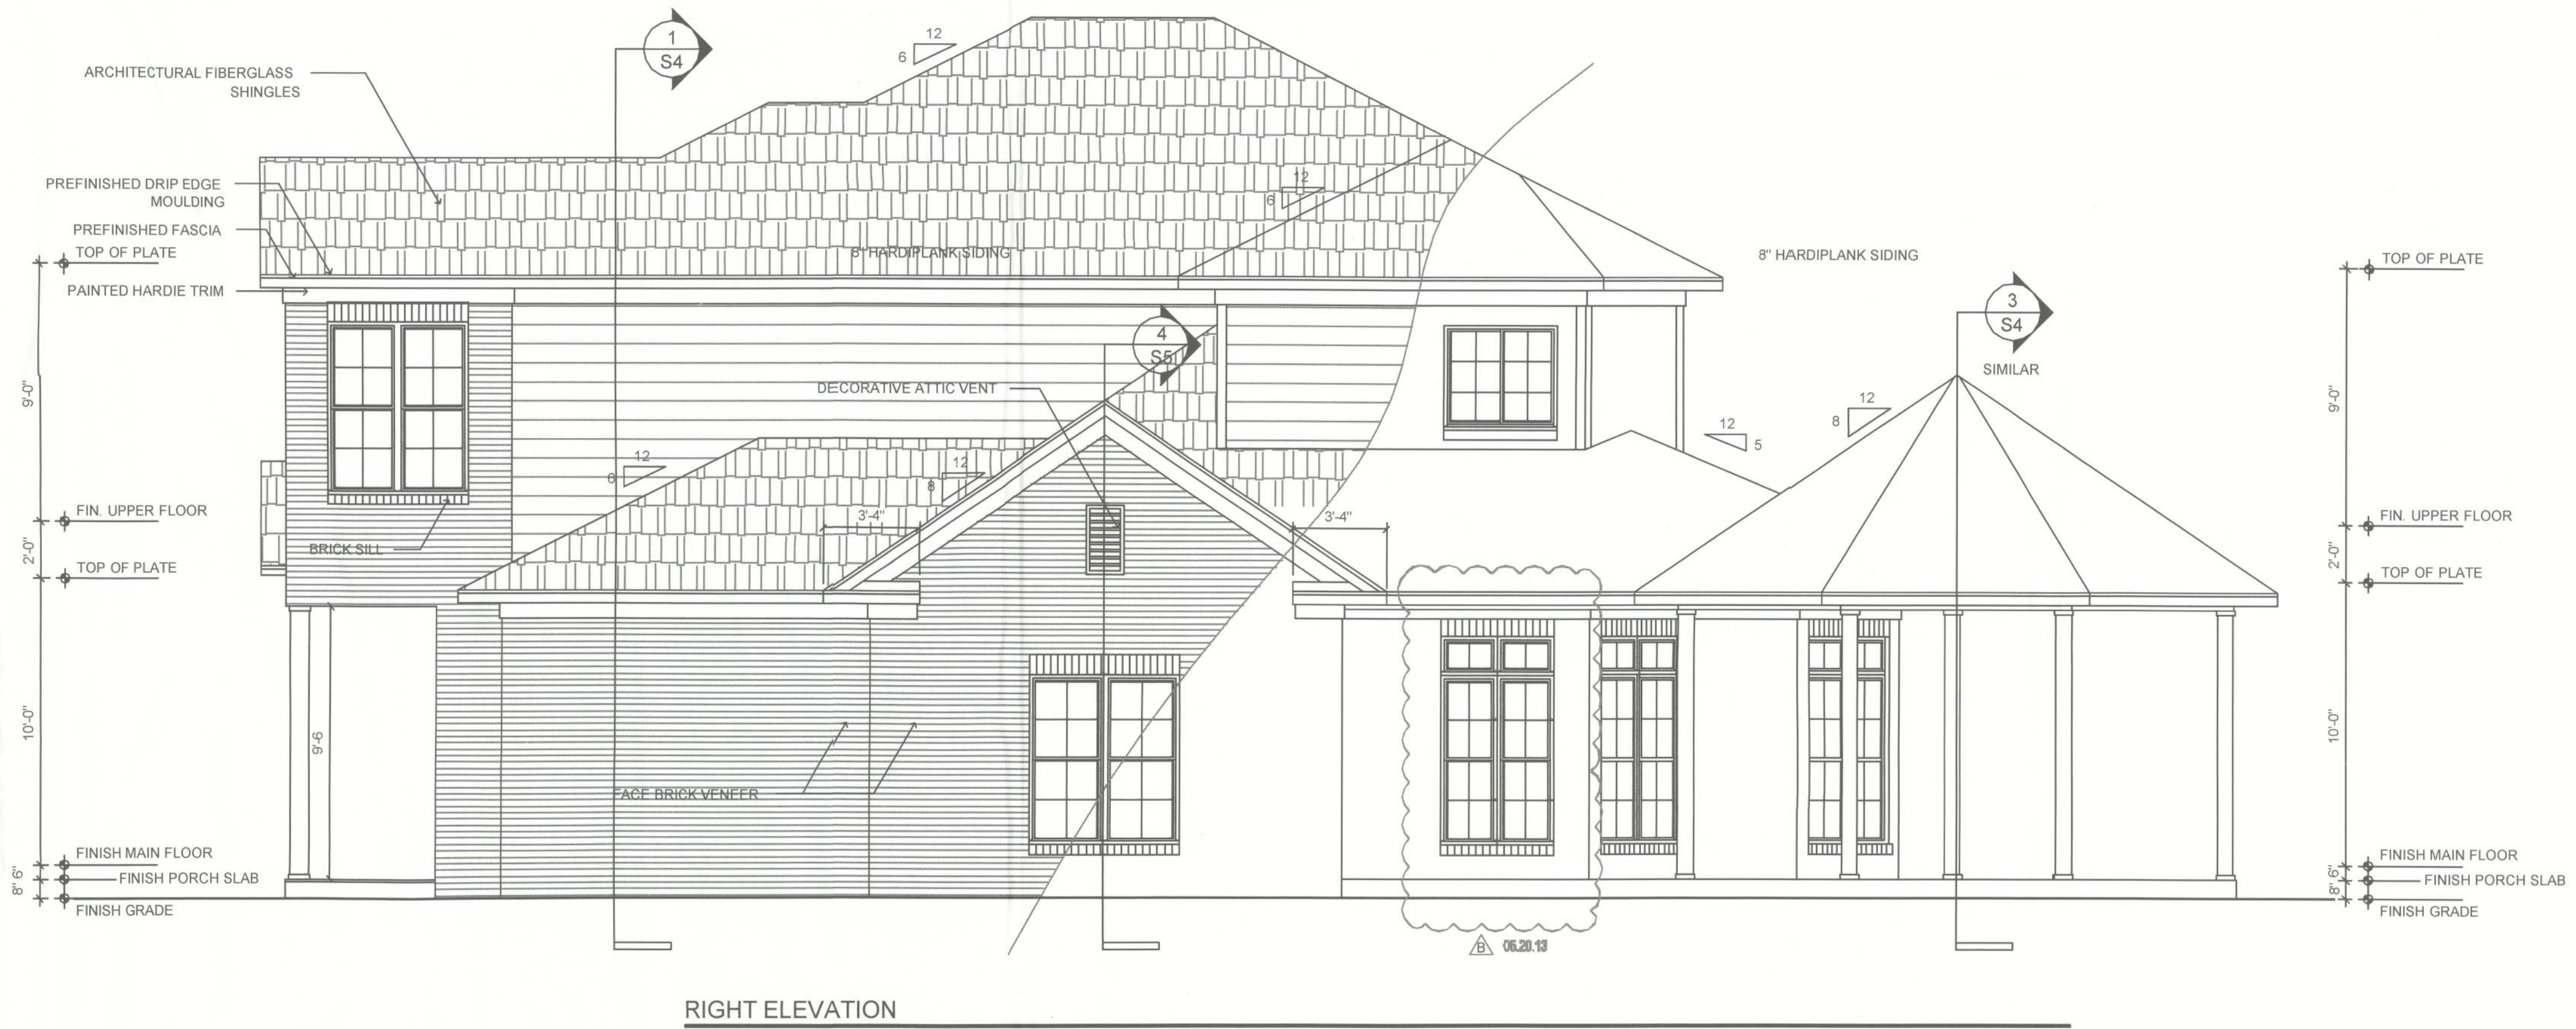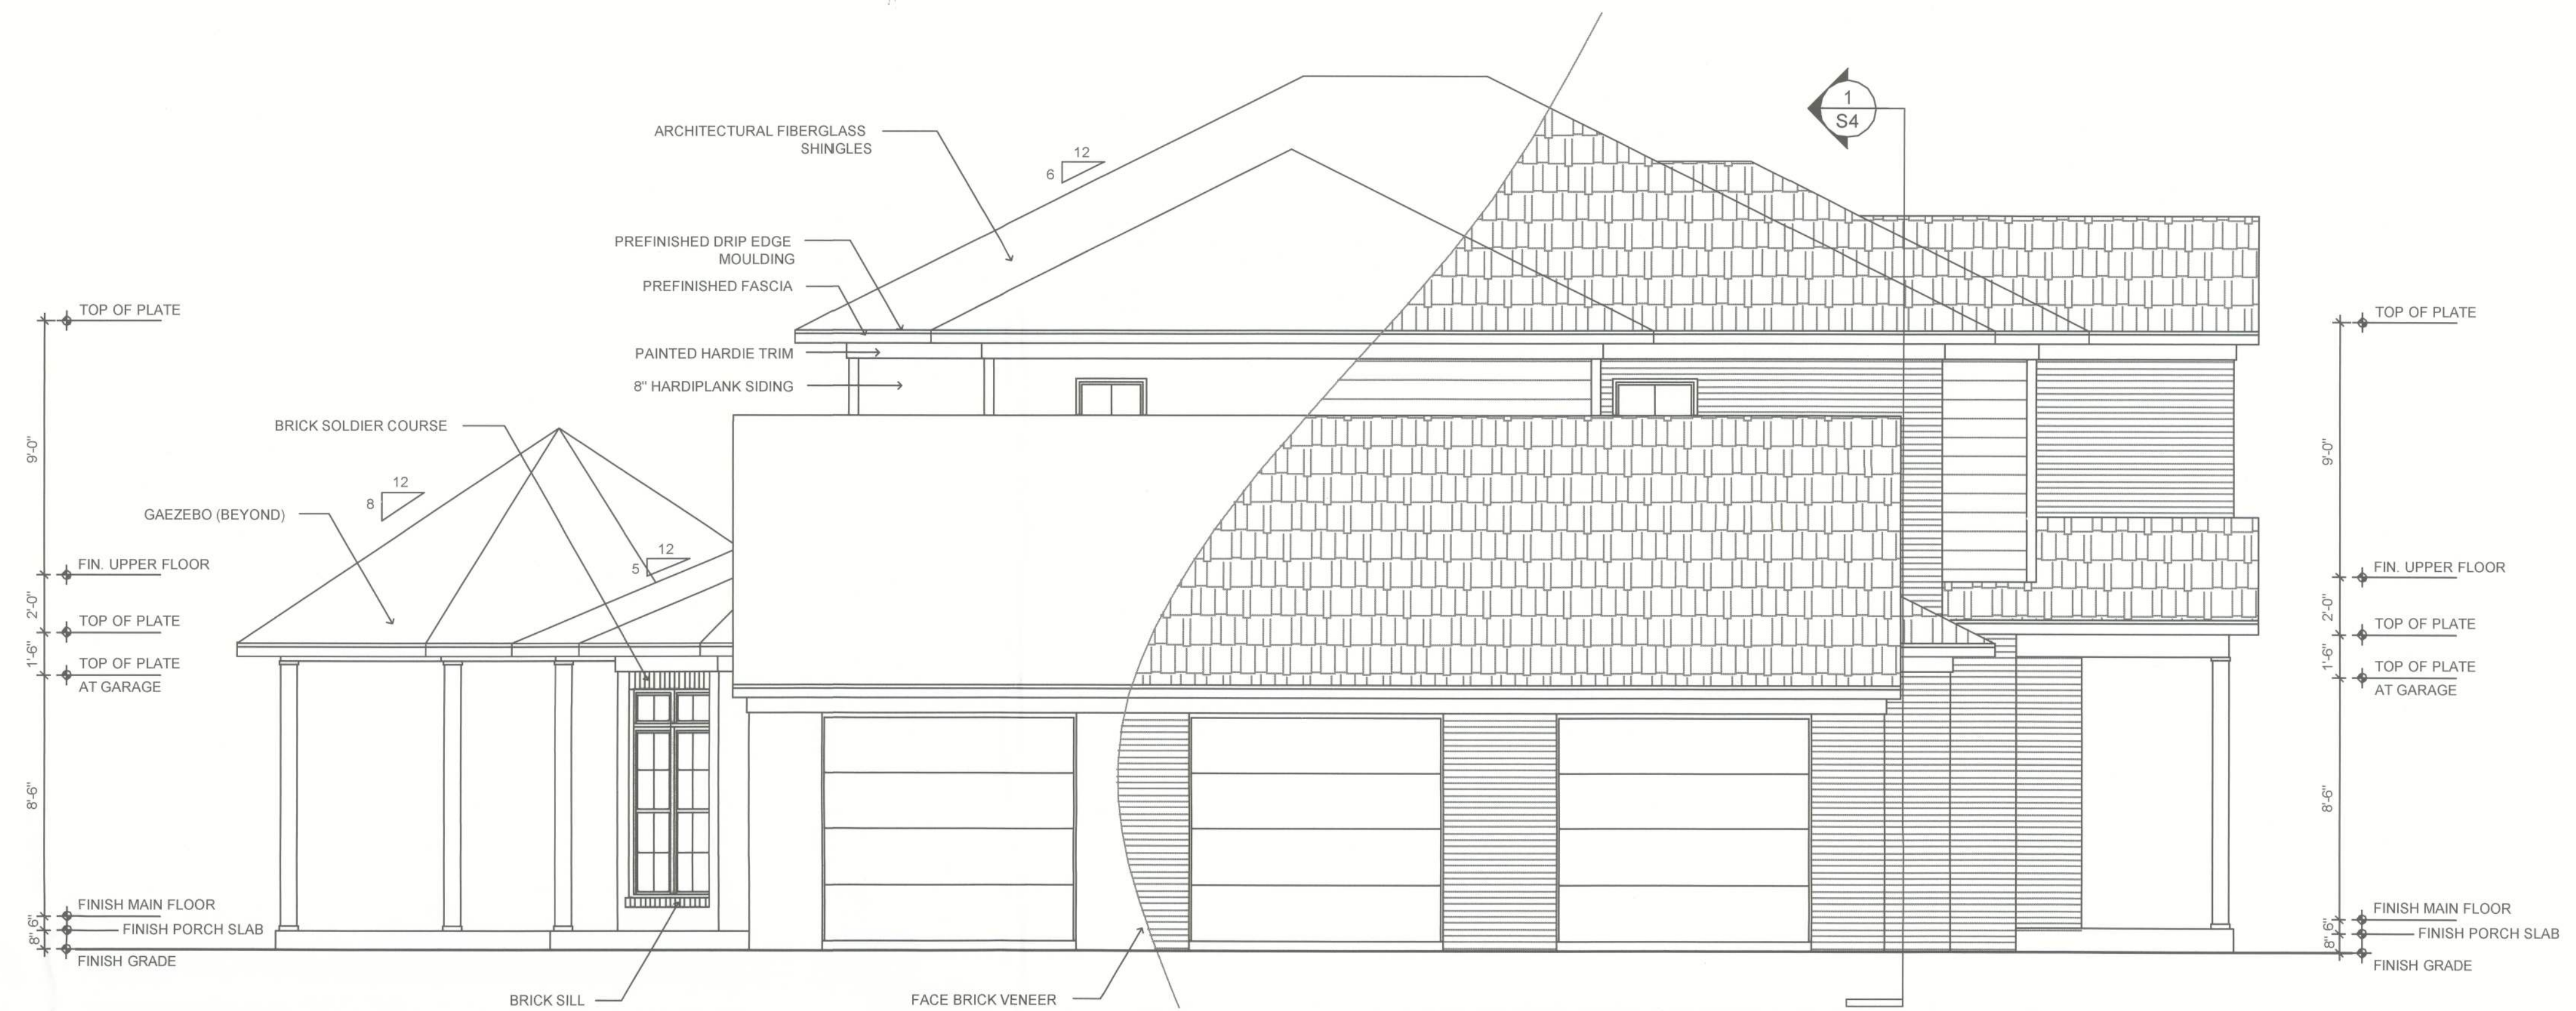

DATE	REMARKS
08.18.13	PERMIT SET
08.20.13	ENLARGE BEDROOM 1

Ken Ehlers P.E. # 18243

5/24/13


STRUCTURAL PLAN SERVICE INC.
 22715
 Post Office Box 940128
 Maitland, FL 32794
 Phone (407) 286-8155
 Fax (407) 286-8141
 Ken Ehlers P.E. # 18243
 LICENSED PROFESSIONAL ENGINEER

PLANS PREPARED BY AND UNDER THE
 DIRECT SUPERVISION OF
 STRUCTURAL PLAN SERVICE, INC.
 AND KEN EHLERS, P.E.

PETER WOODS, RESIDENTIAL DESIGNER
 8834 PESH RD, OCHIA, FL 34472
 peter.woods@residentialdesign.com
 (202) 575-4841

PROPOSED RESIDENCE
 DENNILLE AND A.J. DECKER
 468 NW HACKNEY TERRACE, LAKE CITY, FL 32055
 PARCEL NO. 36-3S-16-02600-000

SHEET NUMBER
A6
 PROJECT NO. 130103

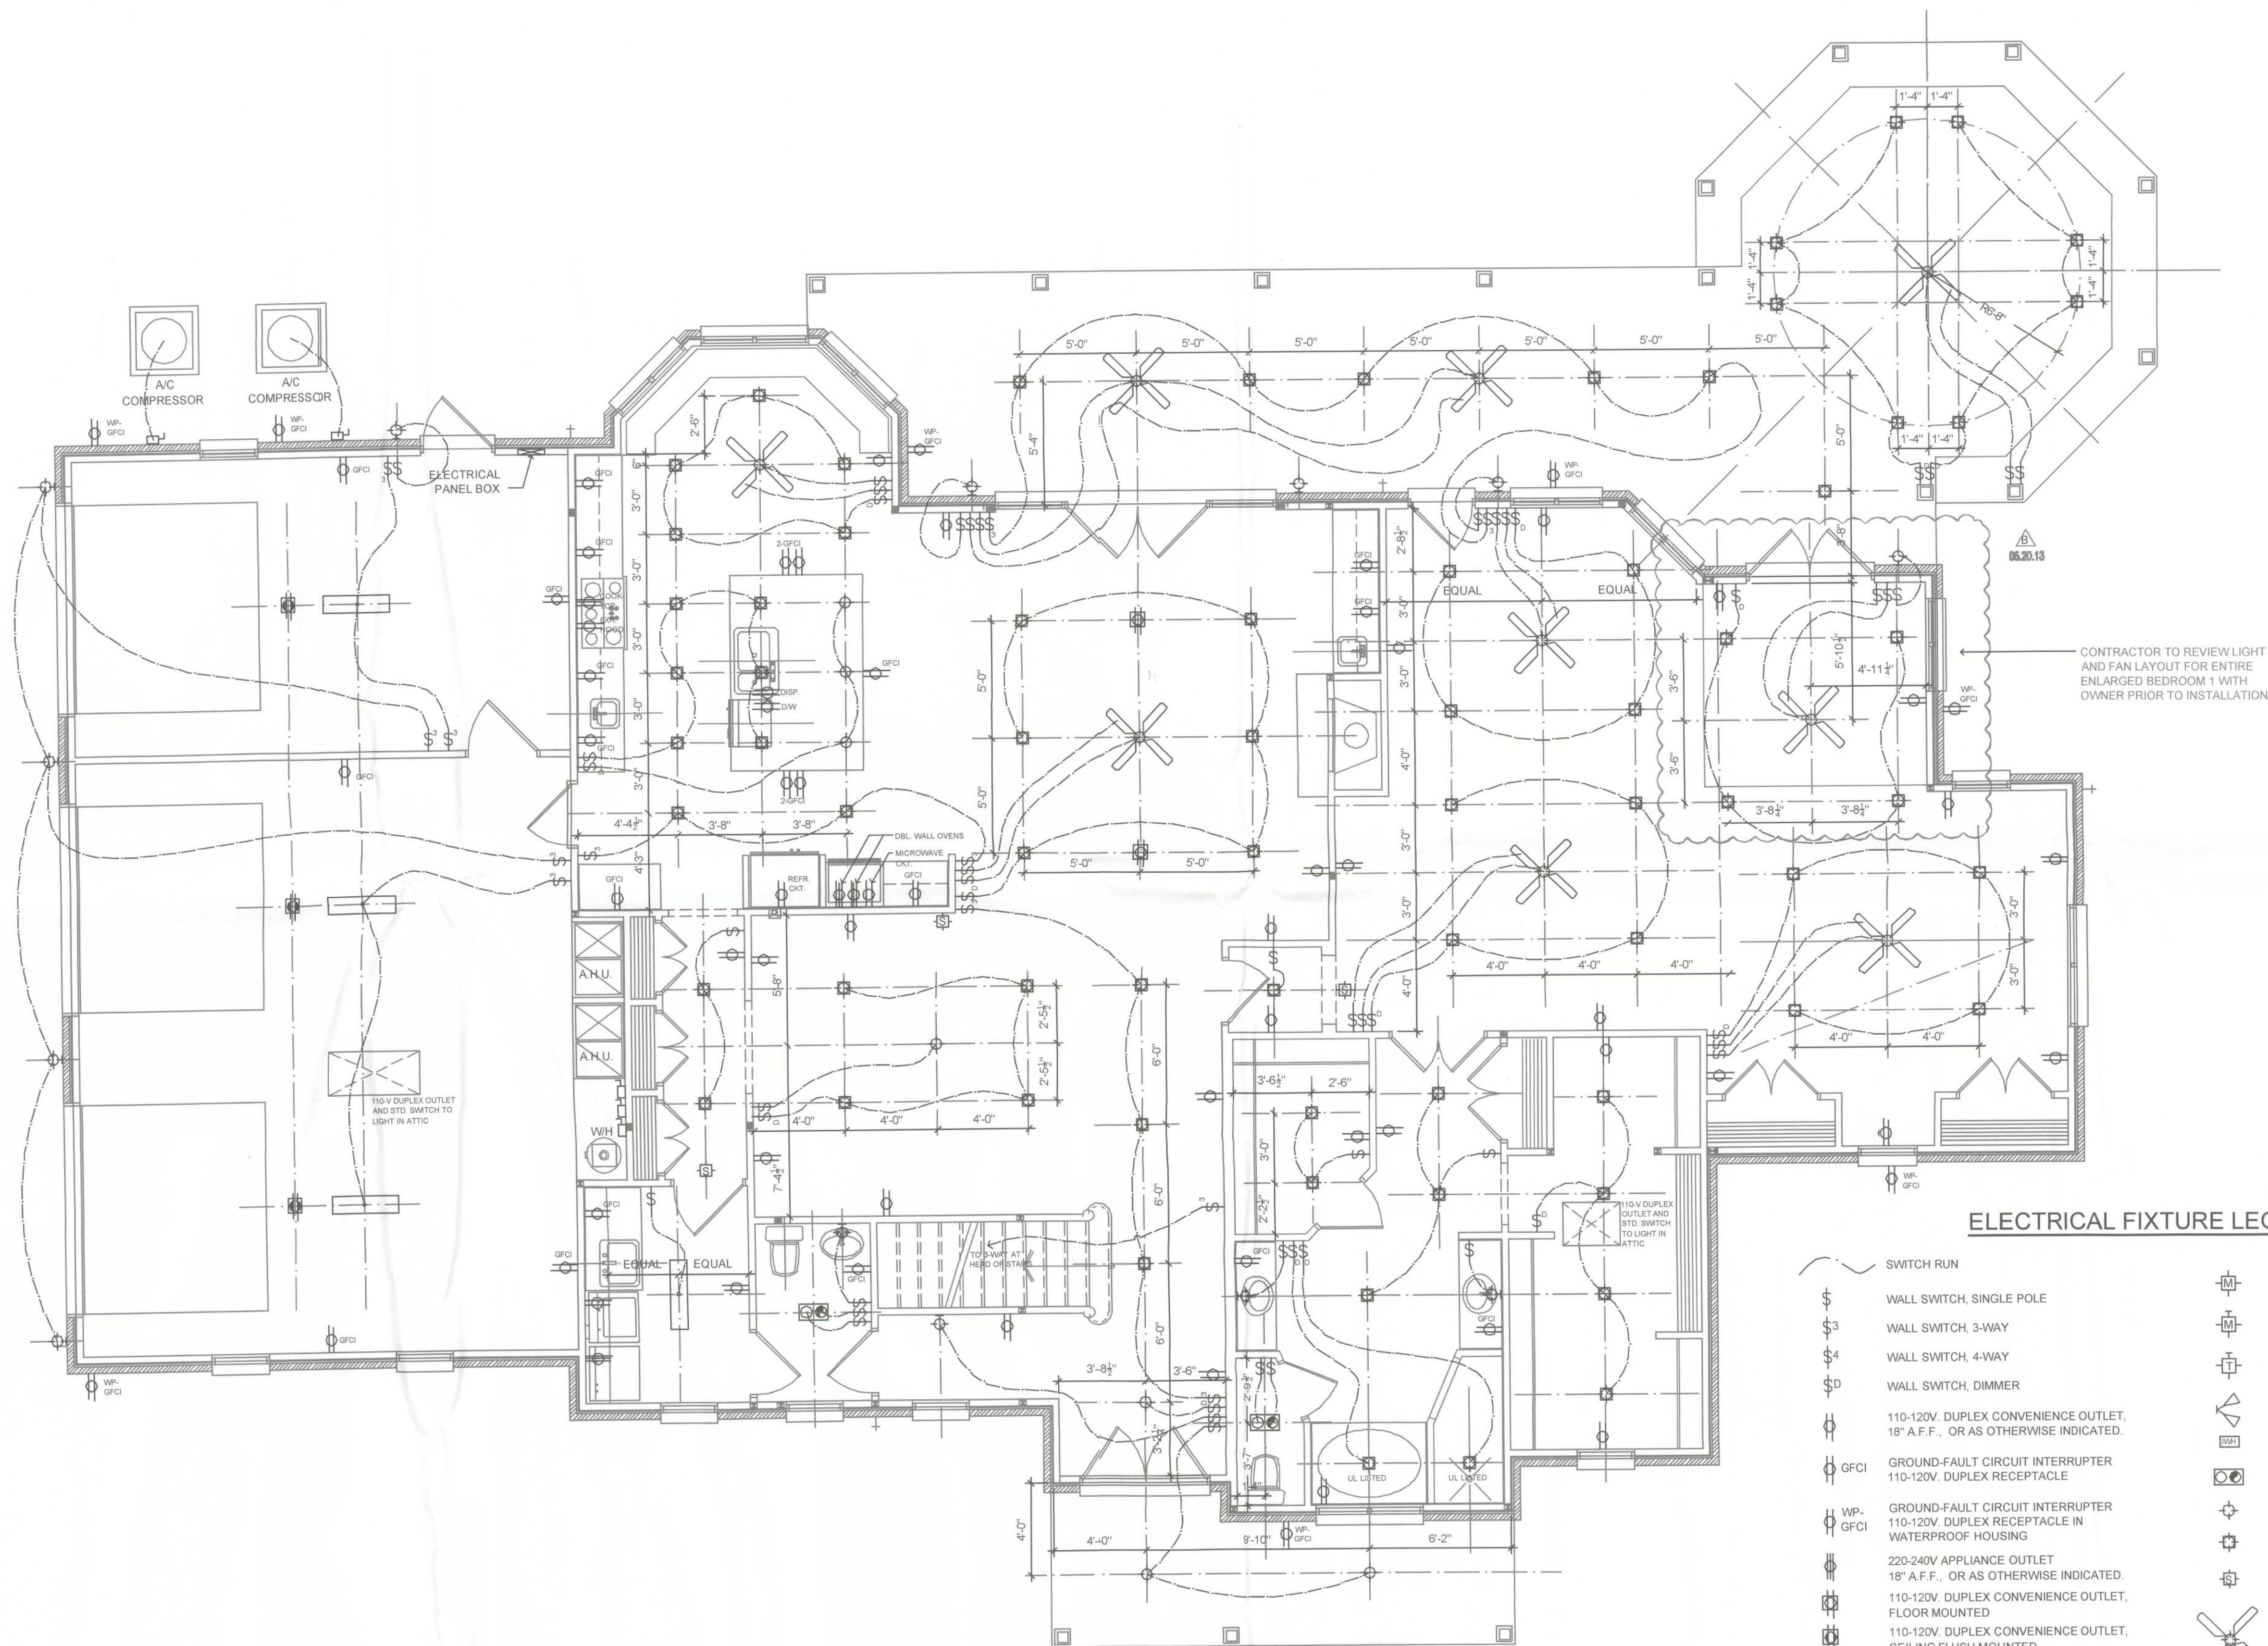

MAIN FLOOR ELECTRICAL PLAN

ALL RECEPTACLES, LIGHTING, AND SAFETY PROTECTION DEVICES (I.E. SMOKE DETECTORS, CARBON MONOXIDE DETECTORS, ETC.) SHALL BE ON CIRCUITRY PROTECTED BY A U.L.-LISTED ARC-FAULT CIRCUIT INTERRUPTER (EXCEPT IN LAUNDRY, KITCHEN, BATHS, GARAGE AND PORCHES).

ALL RECEPTACLES SHALL BE U.L.-LISTED TAMPER-RESISTANT AND OUTDOOR GFCI RECEPTACLES SHALL BE WEATHER-RESISTANT.

PROVIDE SMOKE DETECTORS IN ALL SLEEPING ROOMS AND WITHIN THE IMMEDIATE VICINITY OF SLEEPING ROOMS AND CARBON MONOXIDE DETECTORS WITHIN 10 FEET OF ALL SLEEPING ROOMS.

ALL SMOKE DETECTORS ARE TO HAVE BATTERY BACK-UP AND BE HARD-WIRED AND INTERCONNECTED SO THAT IN THE EVENT THAT ONE IS ACTIVATED, ALL ARE ACTIVATED.

ELECTRICAL FIXTURE LEGEND

- | | |
|--|---|
| SWITCH RUN | MEDIA OUTLET, FLOOR MOUNTED |
| WALL SWITCH, SINGLE POLE | MEDIA OUTLET, 18" A.F.F., OR AS OTHERWISE INDICATED |
| WALL SWITCH, 3-WAY | TELEPHONE OUTLET, 18" A.F.F., OR AS OTHERWISE INDICATED |
| WALL SWITCH, 4-WAY | DOUBLE ADJUSTABLE FLOOD LIGHT |
| WALL SWITCH, DIMMER | INSTANTANEOUS WATER HEATER |
| 110-120V. DUPLEX CONVENIENCE OUTLET, 18" A.F.F., OR AS OTHERWISE INDICATED. | COMBO FAN/LIGHT |
| GROUND-FAULT CIRCUIT INTERRUPTER 110-120V. DUPLEX RECEPTACLE | CEILING LIGHT SURFACE MOUNTED, 150W. MAX. |
| GROUND-FAULT CIRCUIT INTERRUPTER 110-120V. DUPLEX RECEPTACLE IN WATERPROOF HOUSING | CEILING LIGHT RECESS MOUNTED, 150W. MAX. |
| 220-240V APPLIANCE OUTLET, 18" A.F.F., OR AS OTHERWISE INDICATED. | COMBO SMOKE / CARBON MONOXIDE ALARM HARD-WIRED & INTERCONNECTED |
| 110-120V. DUPLEX CONVENIENCE OUTLET, CEILING FLUSH MOUNTED | CEILING FAN WITH LIGHT KIT |
| POWER SWITCH / DISCONNECT | 4-LAMP FLUORESCENT WITH ACRYLIC LENS SURFACE MOUNT |
| WALL LIGHT / SCONCE SURFACE MOUNTED, 150W. MAX. | LED ROPE LIGHT (INDIRECT) |
| COACH LIGHT SURFACE MOUNTED, 150W. MAX. | |

DATE	REMARKS
03.18.13	PERMIT SET
06.20.10	ENLARGE BEDROOM 1

Ken Ehlers P.E.# 18243


STRUCTURAL PLAN SERVICE INC.
COA #27152
Post Office Box 940128
Miami, FL 33198-0128
Tel (305) 255-8155
Fax (407) 255-8141
Ken Ehlers P.E.# 18243
LICENSED PROFESSIONAL ENGINEER

PLANS PREPARED BY AND UNDER THE DIRECT SUPERVISION OF
STRUCTURAL PLAN SERVICE, INC.
AND KEN EHLERS, P.E.

PETER WOODS, RESIDENTIAL DESIGNER
1824 PECAN RD., OCALA, FL 34472
peter.woods@residentialdesign.com
(352) 575-4984

PROPOSED RESIDENCE
DENNILLE AND A.J. DECKER
468 NW HACKNEY TERRACE, LAKE CITY, FL 32055
PARCEL NO. 36-3S-16-02600-000

SHEET NUMBER
E1
PROJECT NO. 130103

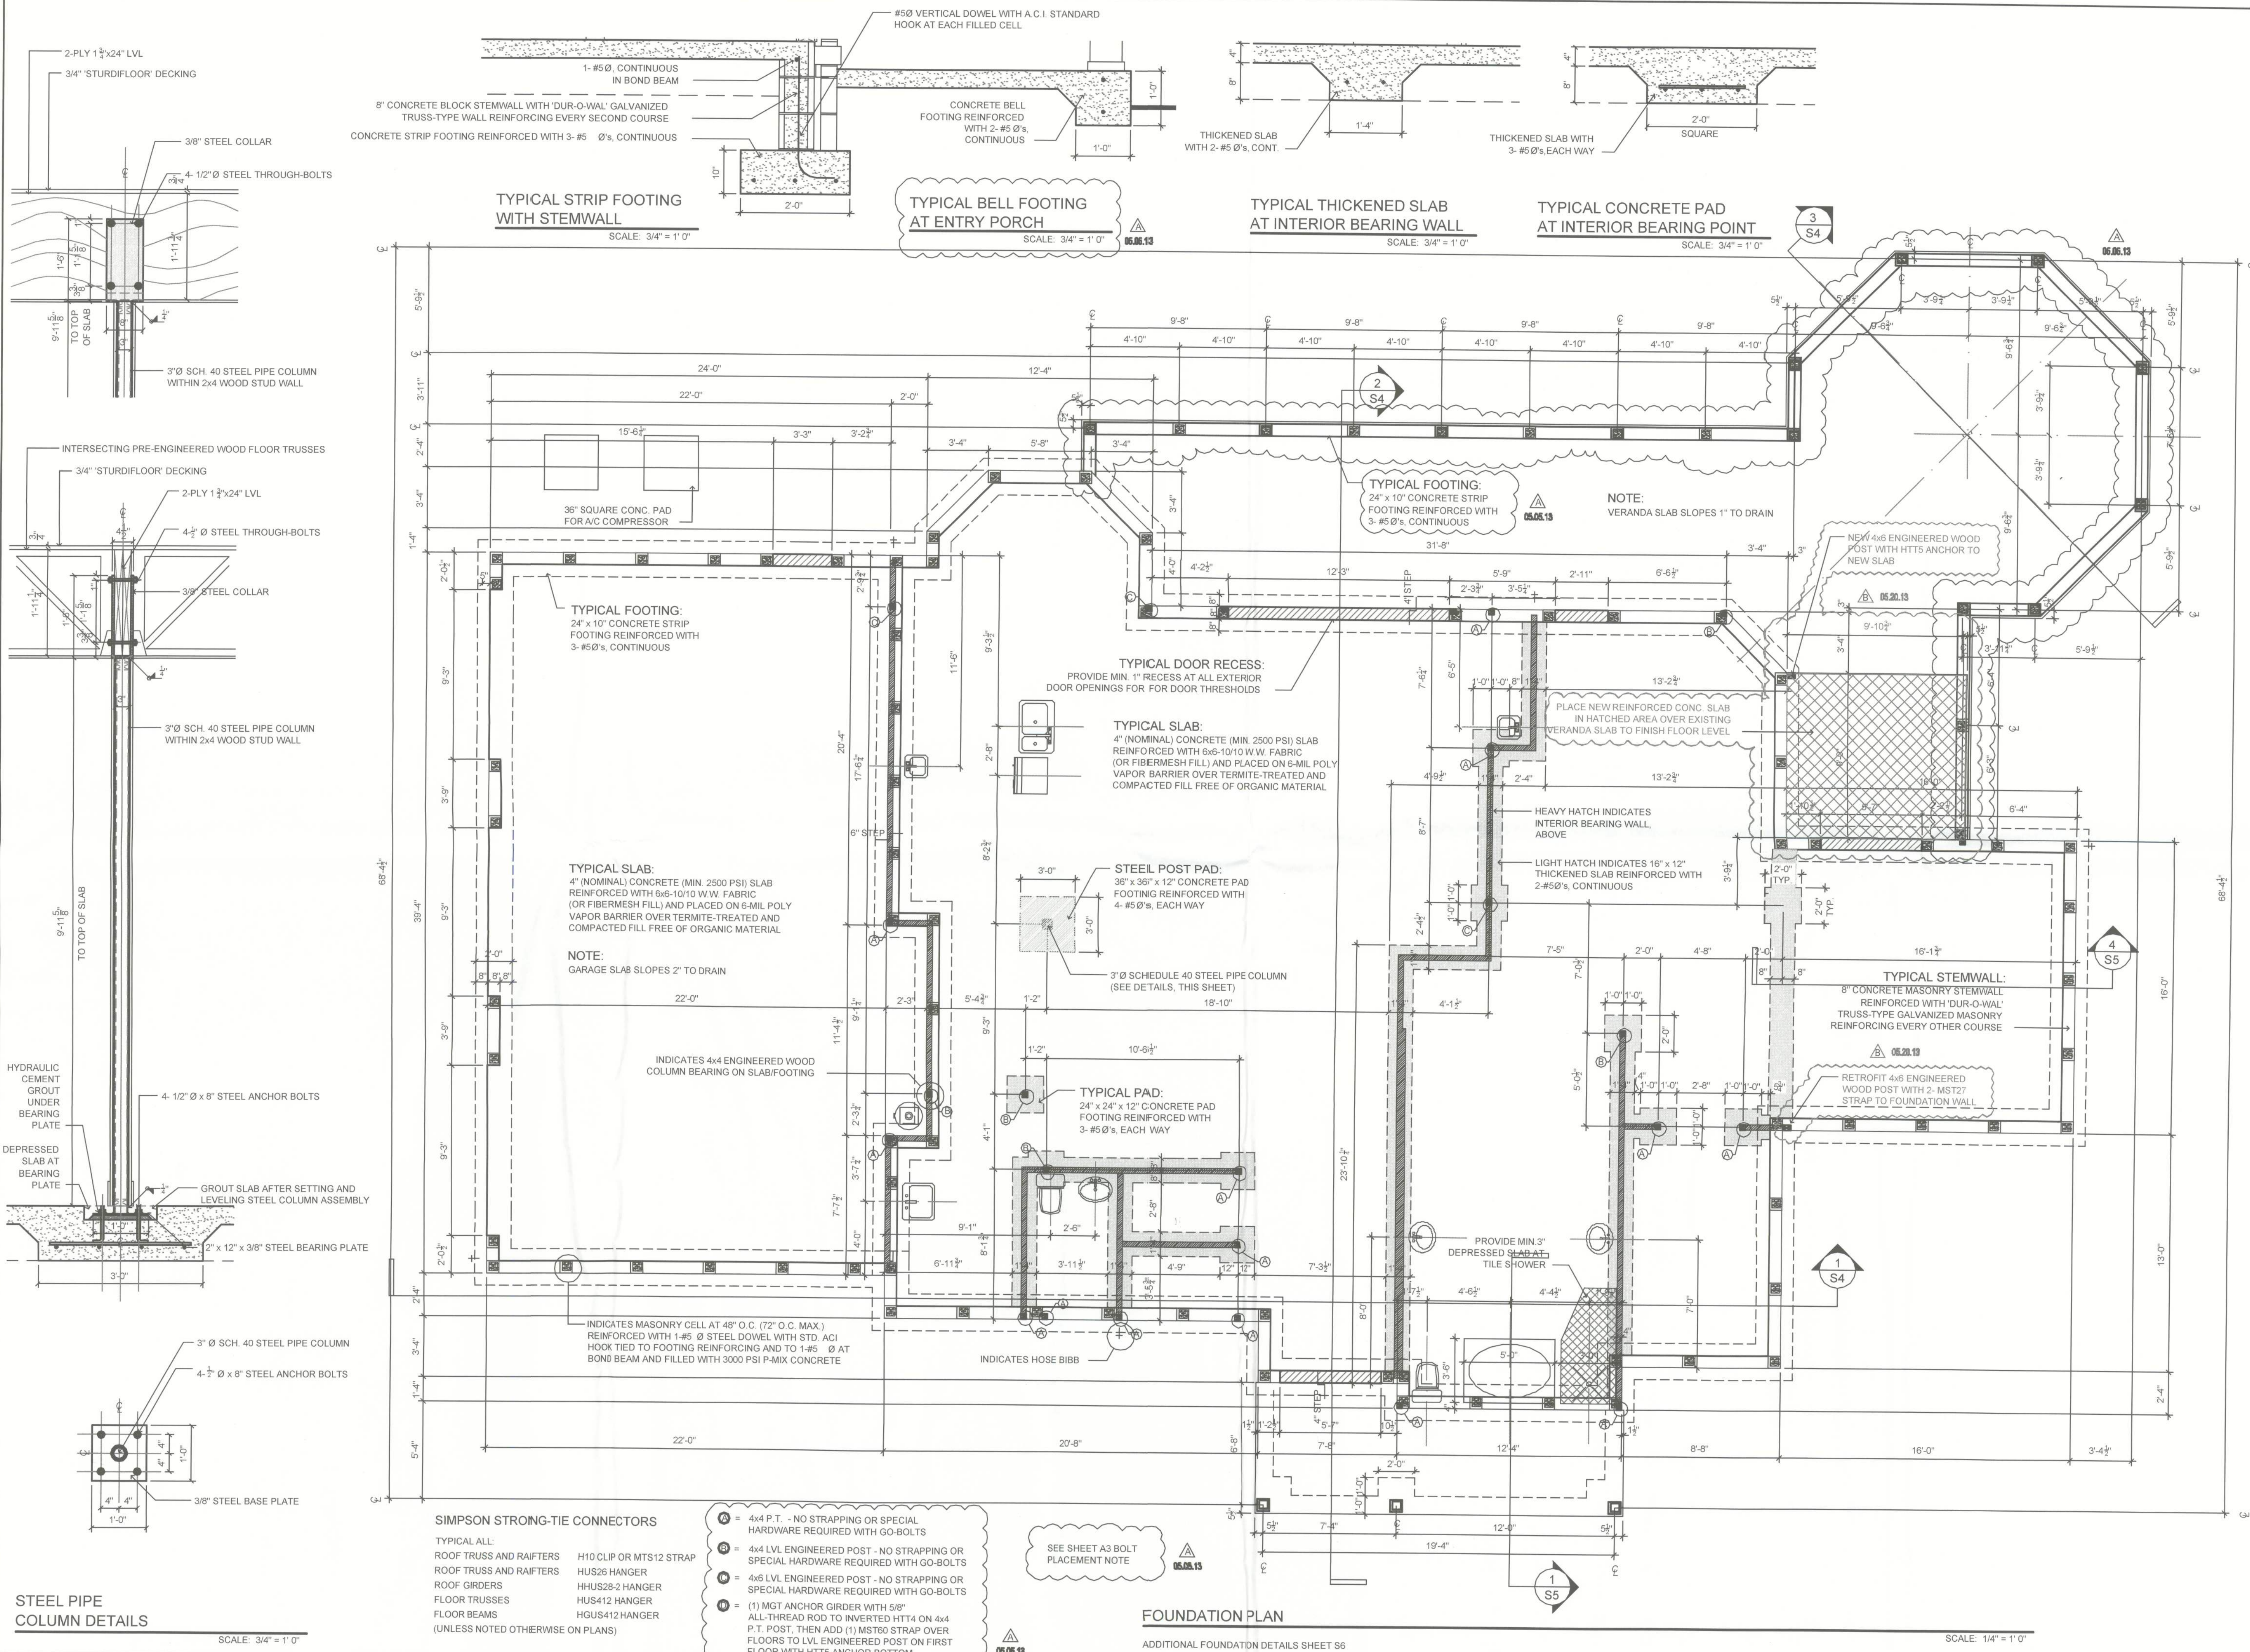

DATE	REMARKS
03.18.13	PERMIT SET
05.05.13	FOOTINGS
05.20.13	ENLARGE BEDROOM 1

Ken Ehlers P.E. # 18243

STRUCTURAL PLAN SERVICE INC.
Post Office Box 940128
Fort Lauderdale, FL 33334
Phone (407) 255-6155
Fax (407) 255-6141
Ken Ehlers P.E. # 18243
LICENSED PROFESSIONAL ENGINEER

SPS


PLANS PREPARED BY AND UNDER THE DIRECT SUPERVISION OF
STRUCTURAL PLAN SERVICE INC.
AND KEN EHLERS, P.E.

PETER WOODS, RESIDENTIAL DESIGNER
1501 PEECAN RD., COALA, FL 34472
peter.woods@residentialdesign.com
(352) 575-4884

PROPOSED RESIDENCE
DENNILLE AND A.J. DECKER
468 NW HACKNEY TERRACE, LAKE CITY, FL 32055
PARCEL NO. 36-3S-16-02600-000

SHEET NUMBER
S1

PROJECT NO. 130103

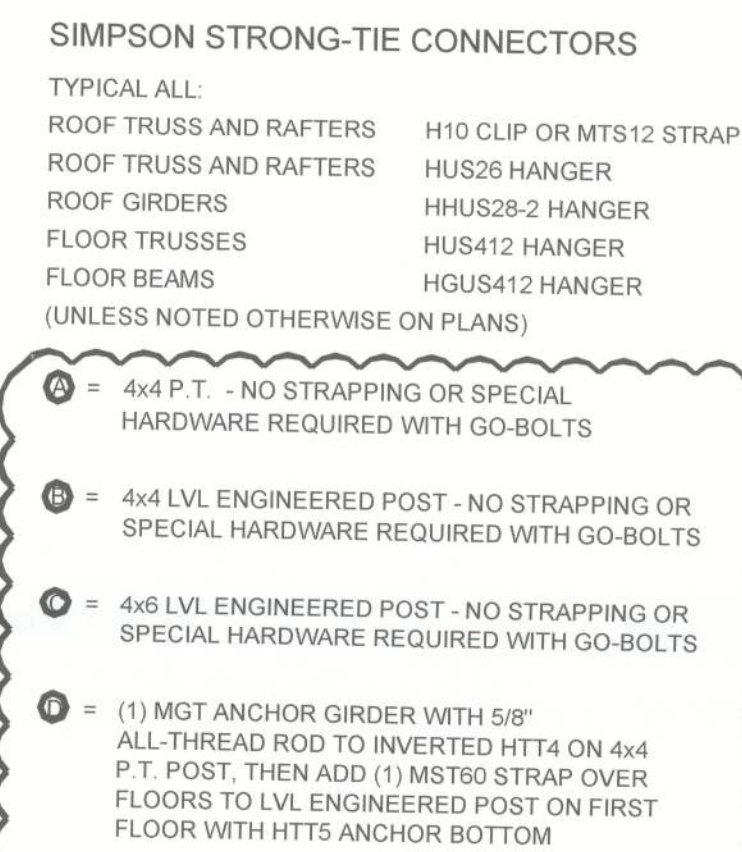

1
S2

Ken Ehlers P.E.# 18243
5/24/13
fclm

SHEET NUMBER

S2

PROJECT NO. 130103

DATE	REMARKS
03.16.13	PERMIT SET
05.05.13	ADD 90-BOLTS, FOOTINGS
05.20.13	ENLARGE BEDROOM 1

Ken Ehlers P.E. # 18243
5/24/13


STRUCTURAL PLAN SERVICE INC.
P.O. Box 940128
Miami, FL 33294
Phone (407) 296-0165
Fax (407) 296-0141
Ken Ehlers P.E. # 18243
LICENSED PROFESSIONAL ENGINEER

PLANS PREPARED BY AND UNDER THE
DIRECT SUPERVISION OF
STRUCTURAL PLAN SERVICE INC.
AND KEN EHLERS, P.E.


PETER WOODS, RESIDENTIAL DESIGNER
5554 PIEDMONT BL., COVINGTON, LA 70422
peter.woods@residentialplan.com
(504) 575-4864

PROPOSED RESIDENCE
DENNILLE AND A.J. DECKER
468 NW HACKNEY TERRACE, LAKE CITY, FL 32055
PARCEL NO. 36-3S-16-02800-000


SHEET NUMBER
S5
PROJECT NO. 130103

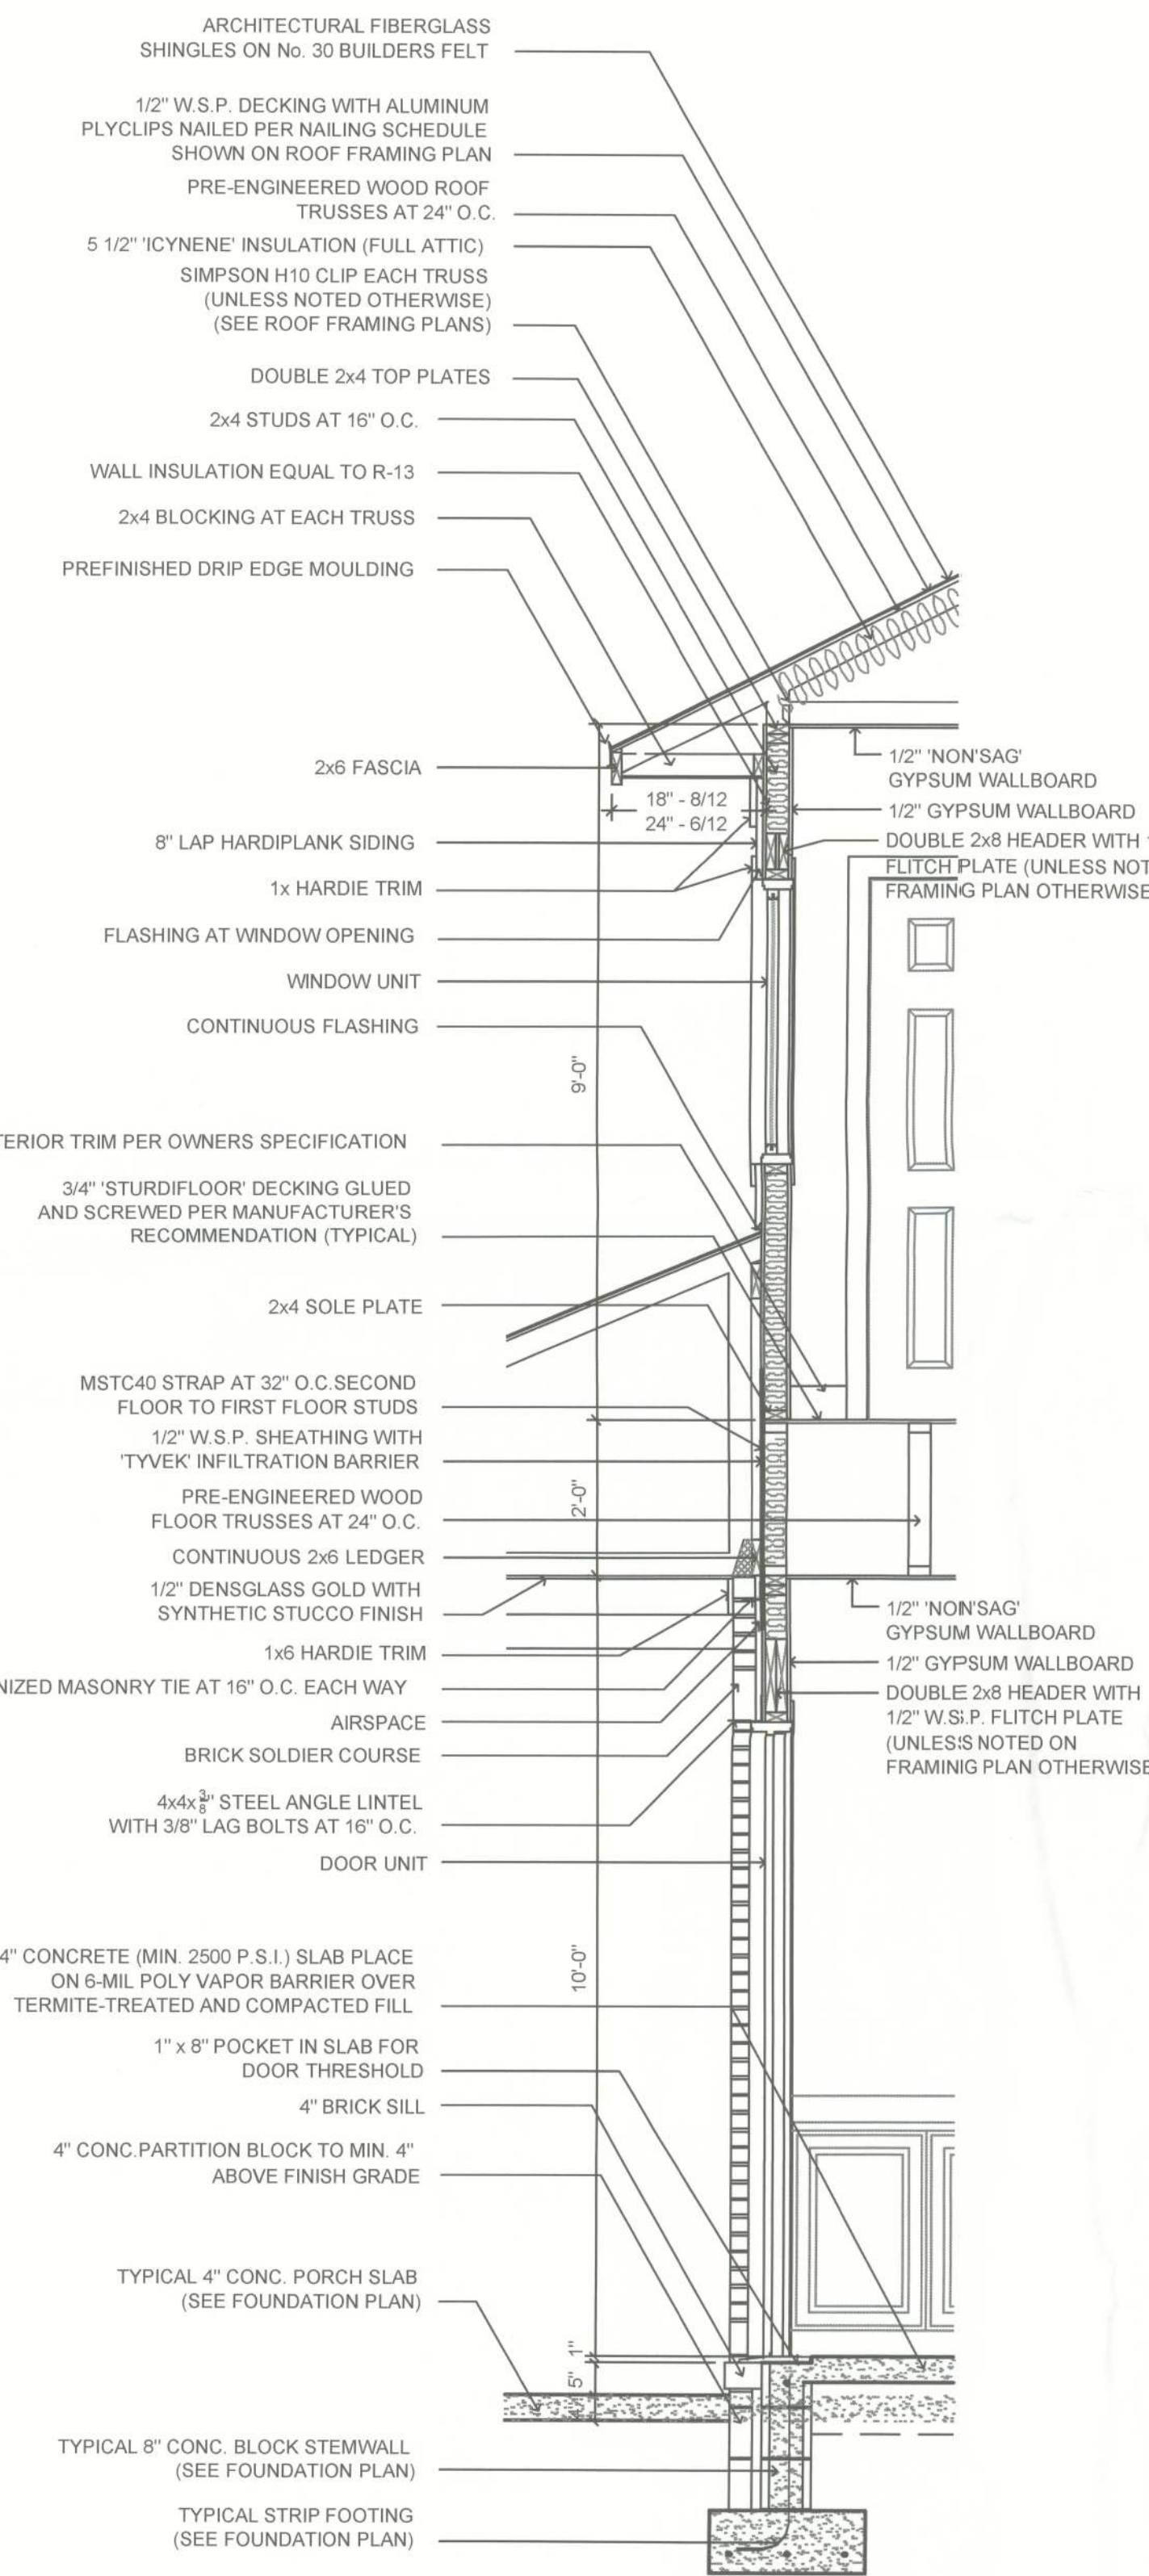


3
S5 TYPICAL WALL SECTION
(TWO STORY)
SCALE: 1/2" = 1' 0"

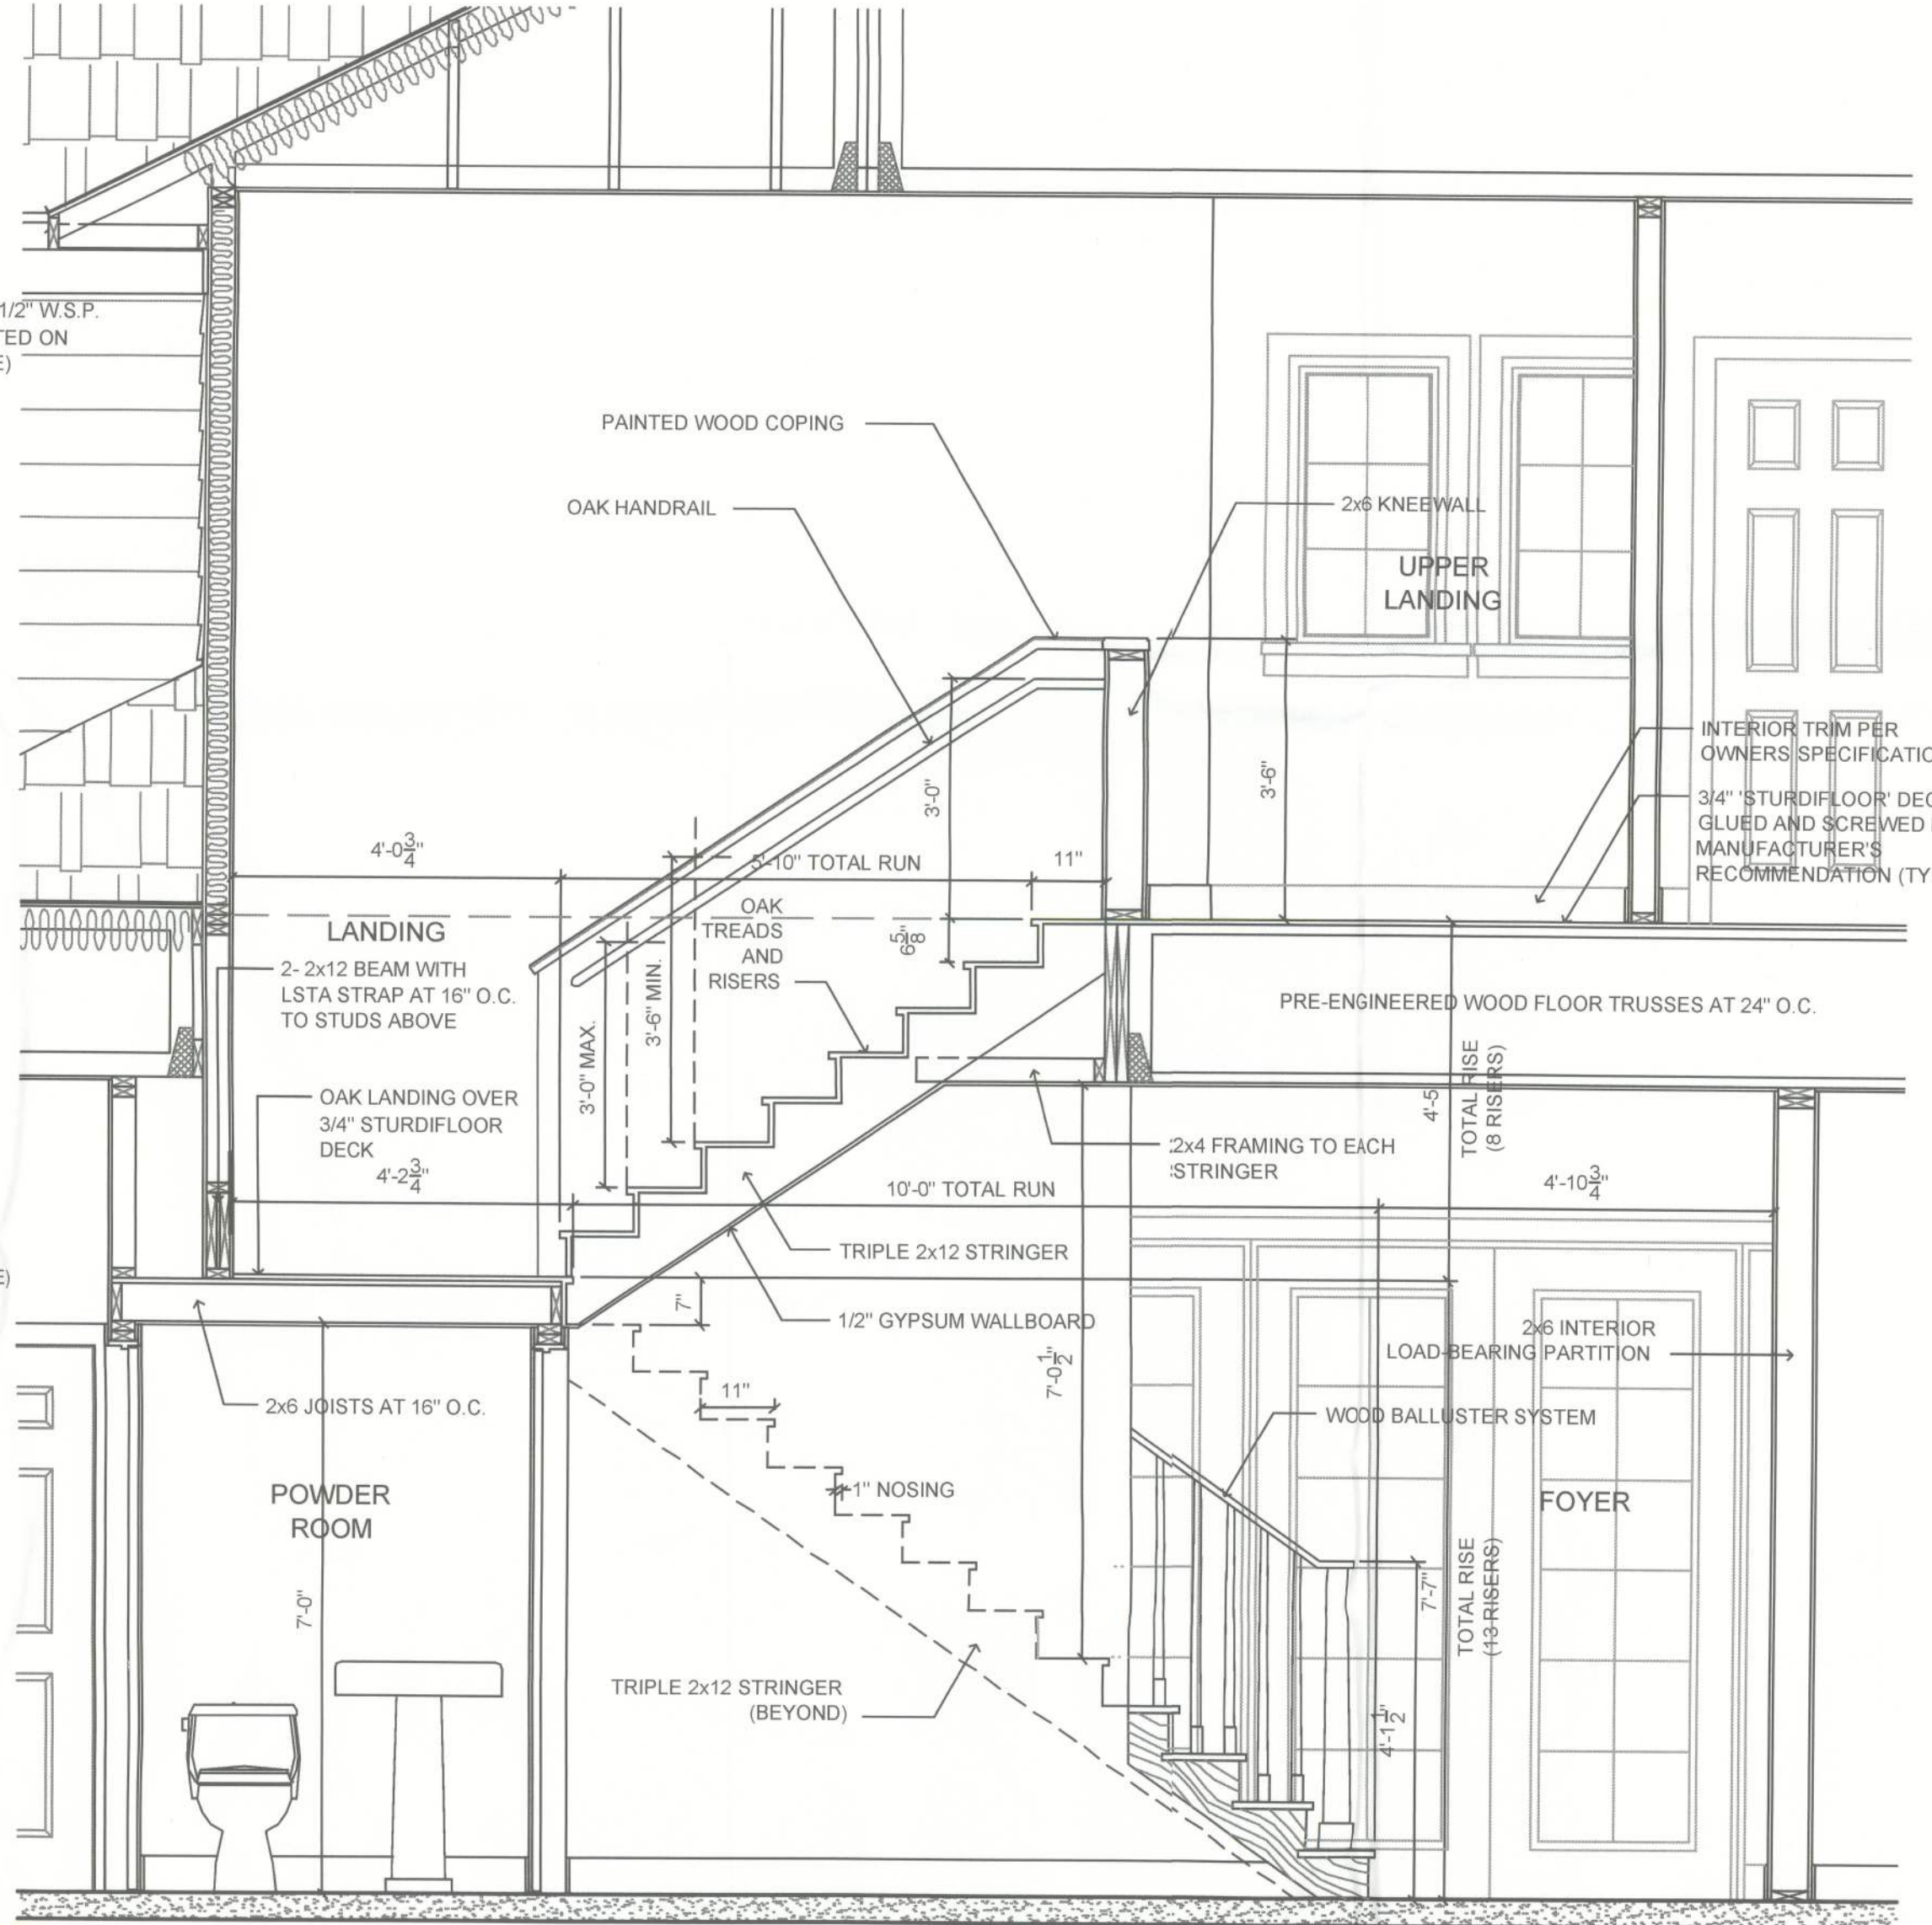

2
S5 STAIRS DETAILS
SCALE: 1/2" = 1' 0"

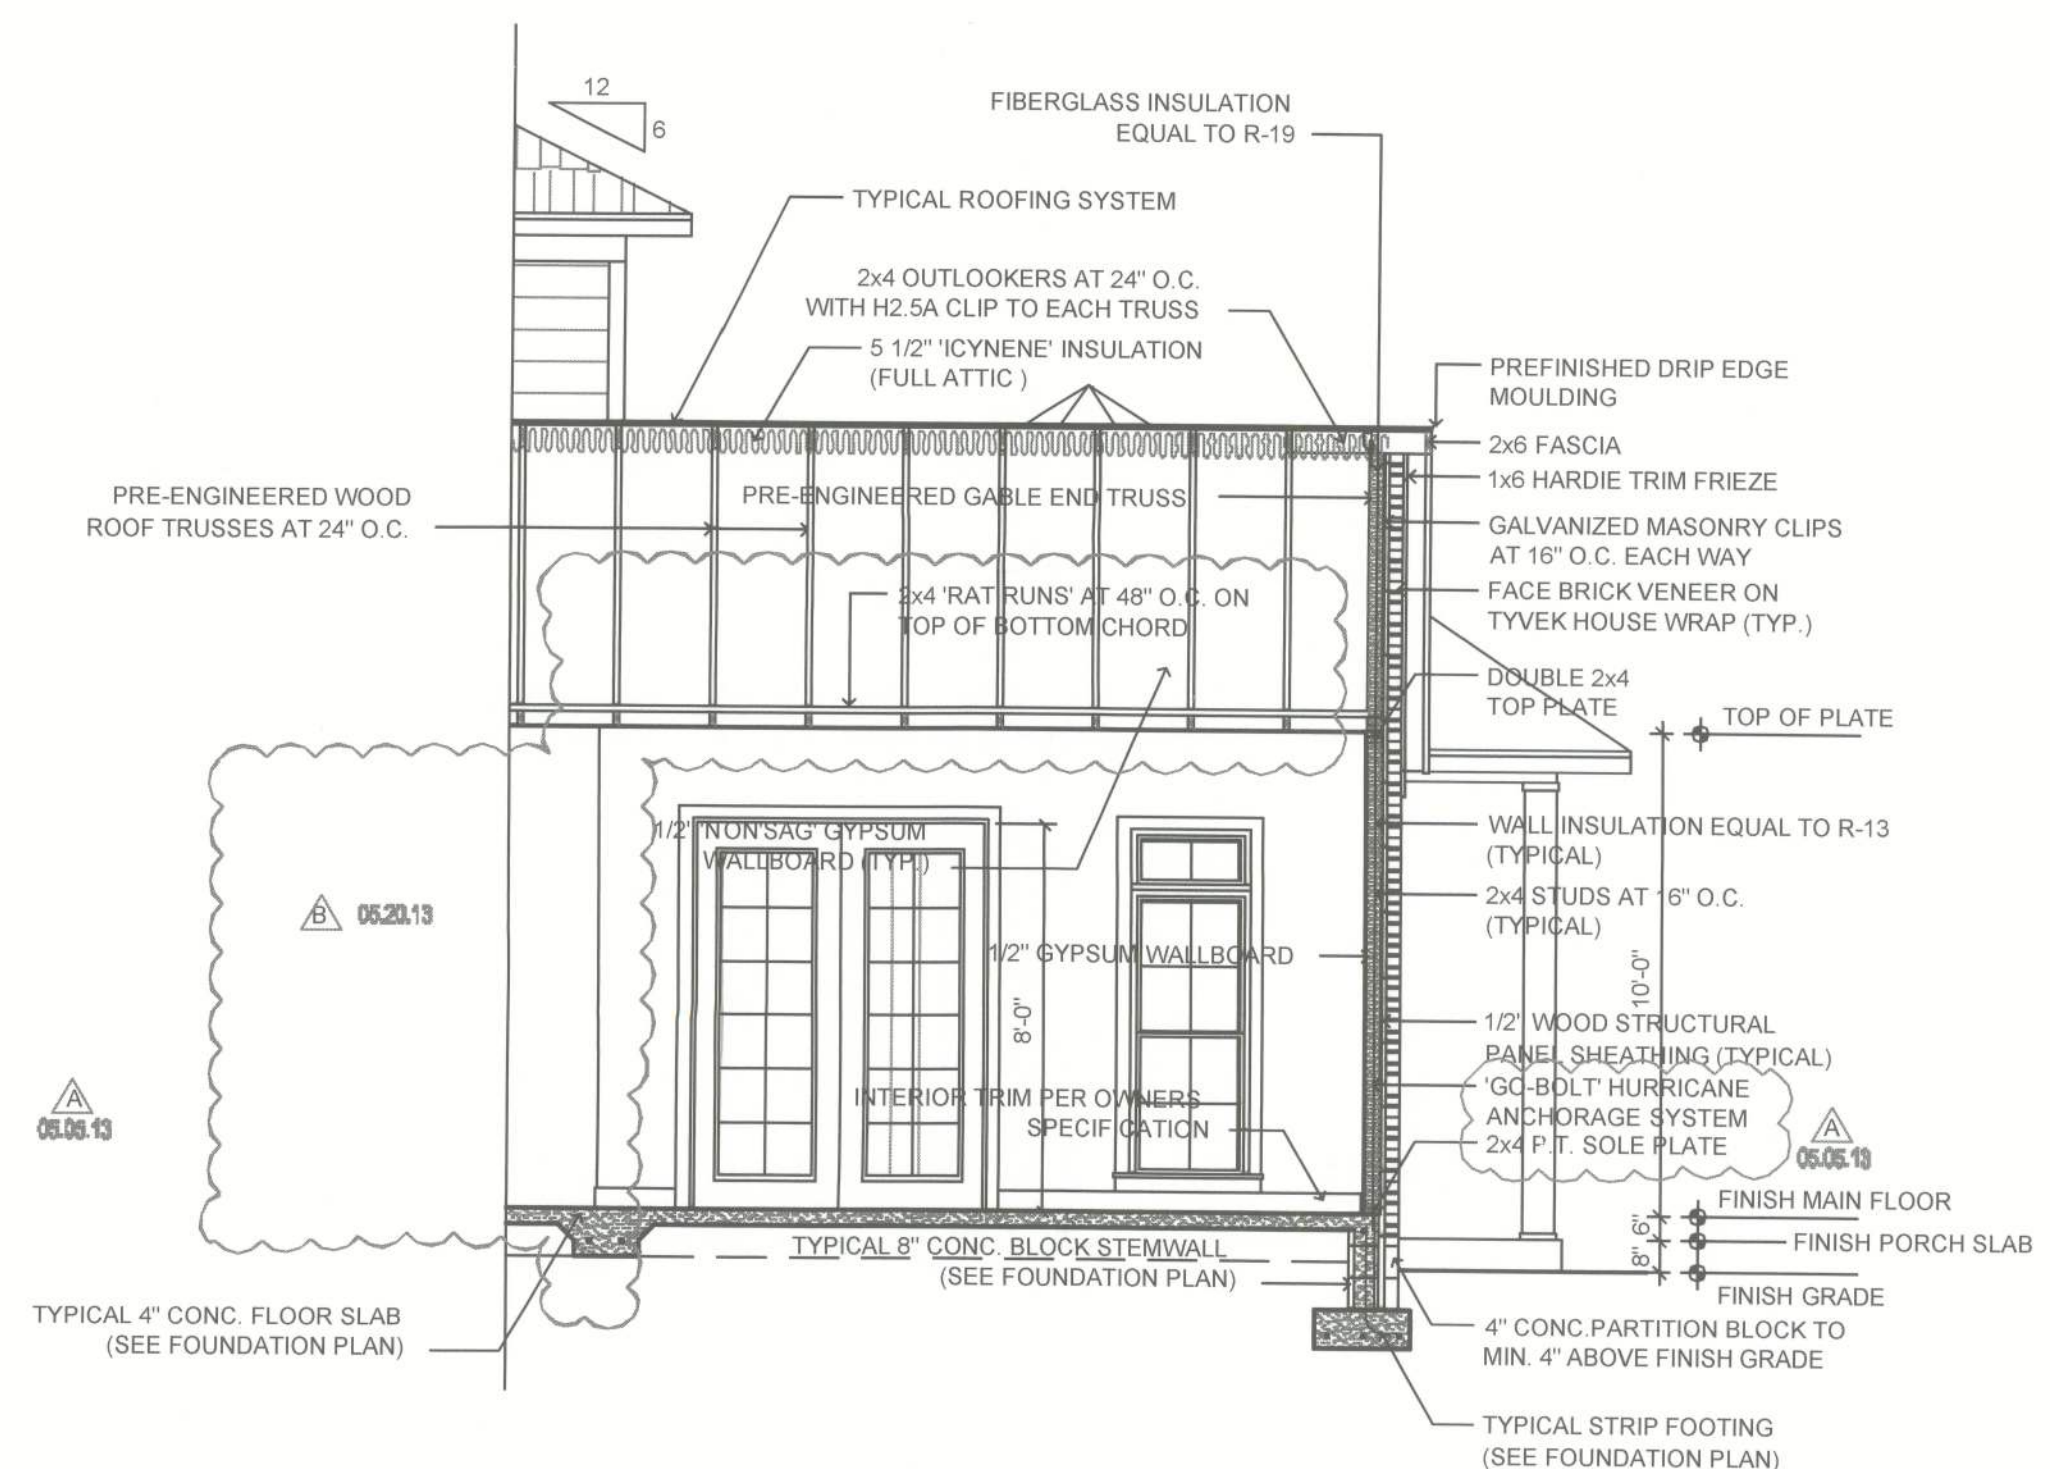

4
S5 SECTION
SCALE: 1/4" = 1' 0"

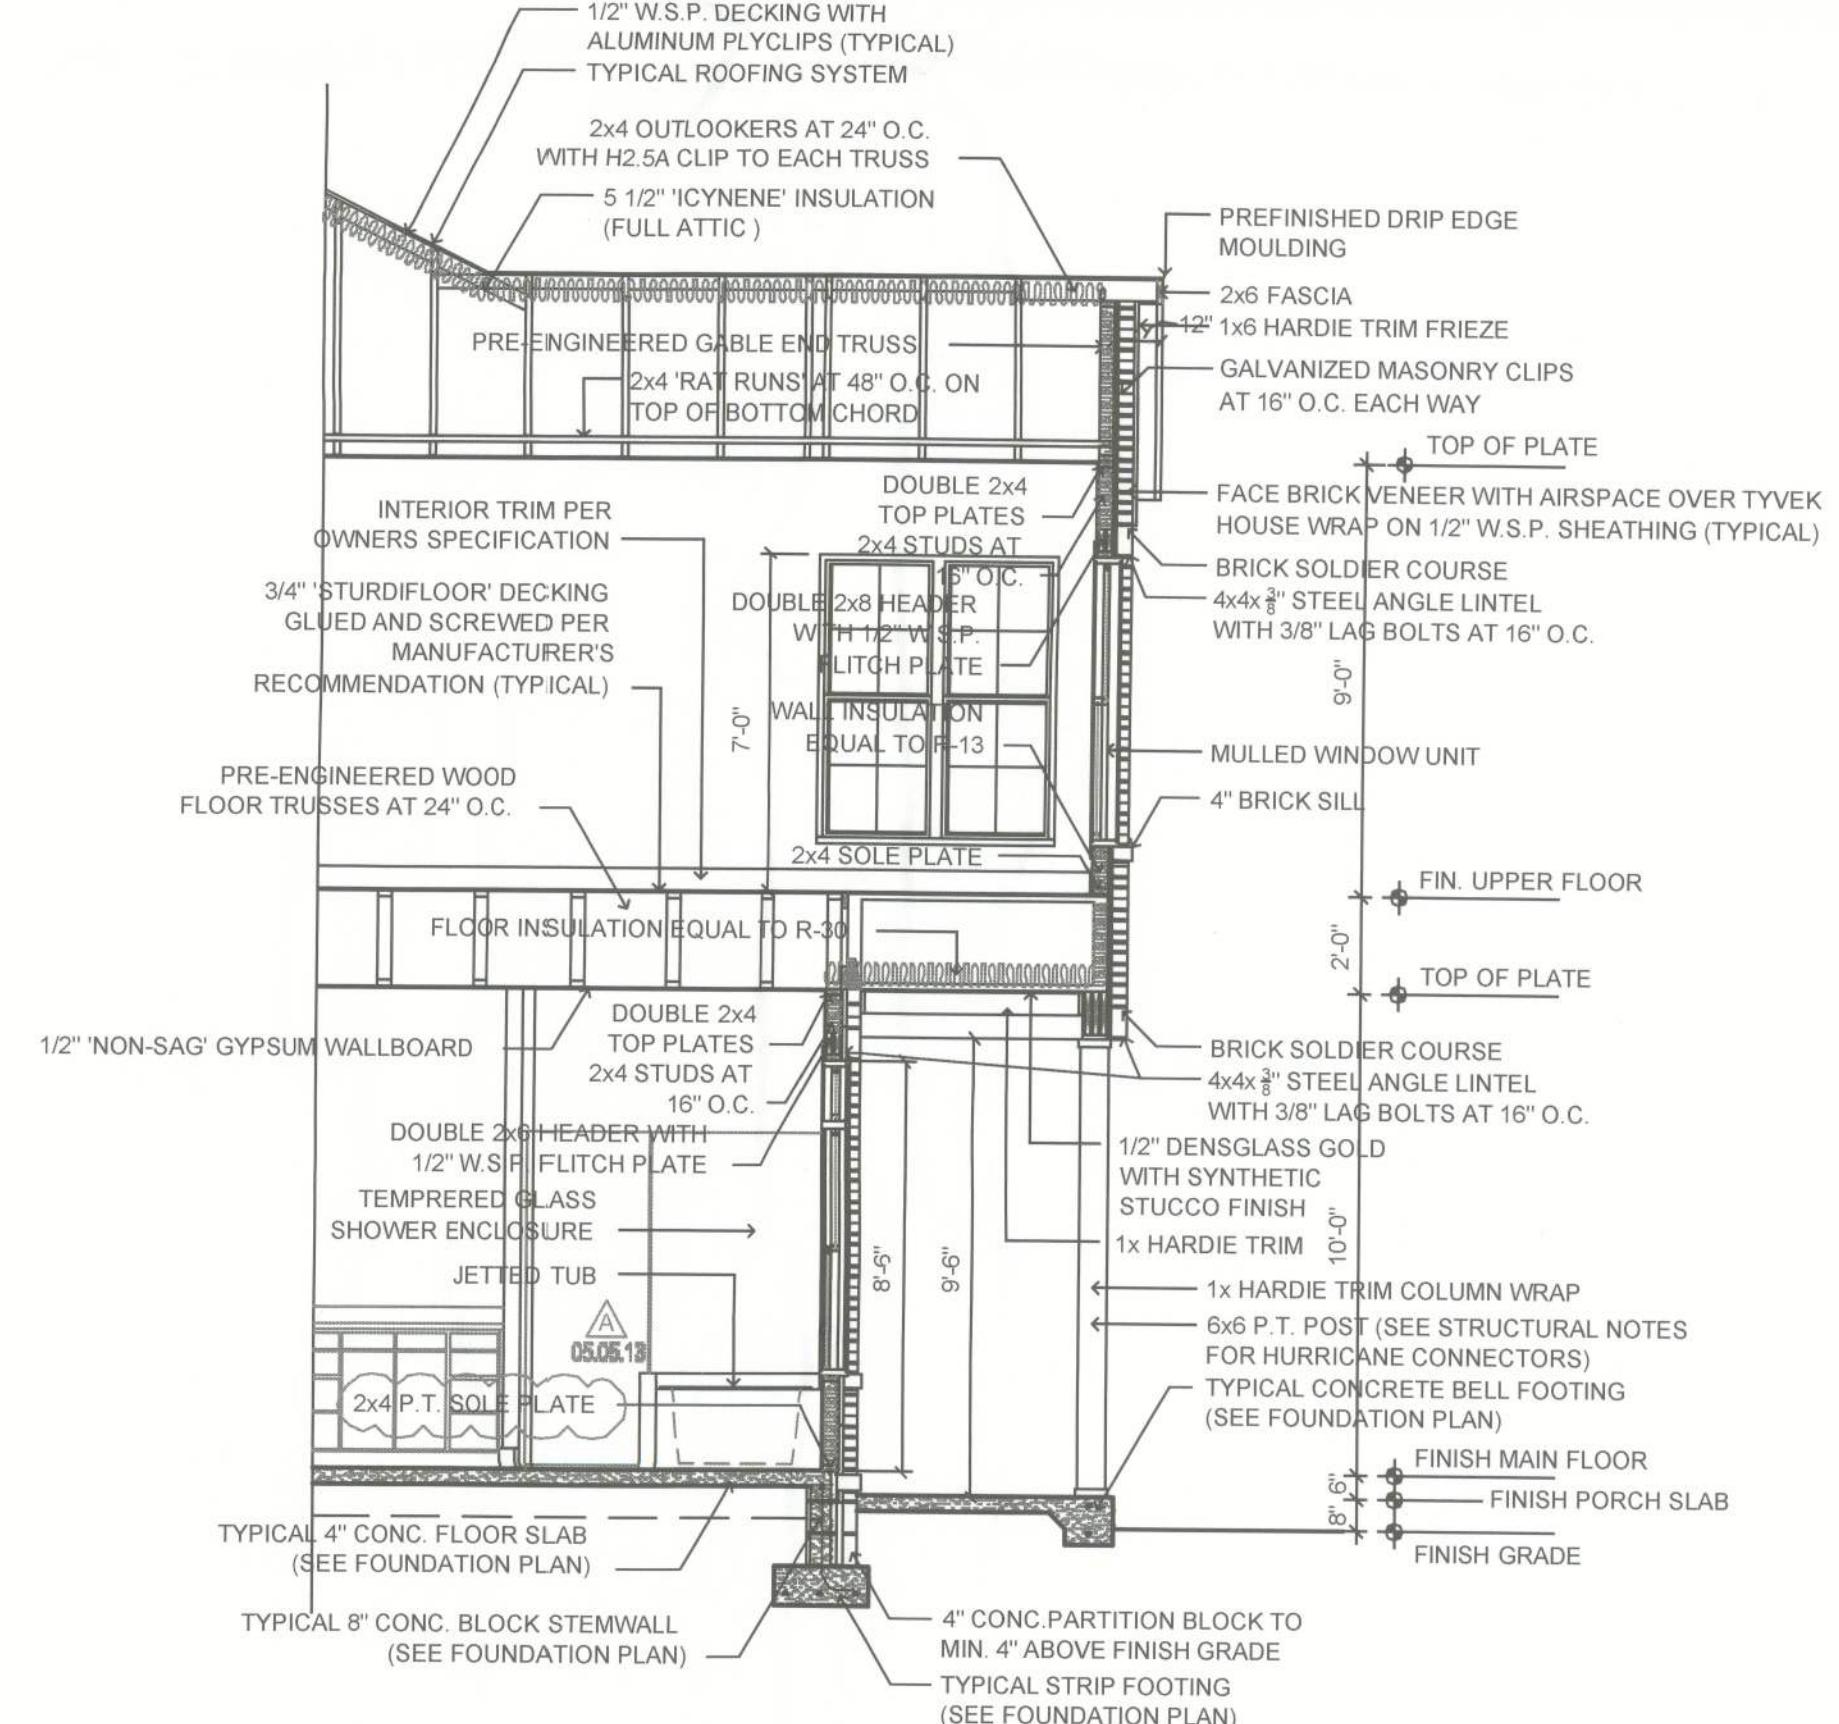

1
S5 SECTION
SCALE: 1/4" = 1' 0"

TYPICAL NOTES:
ANY NOTE DESCRIBING A TYPICAL CONDITION SHALL APPLY TO ALL SIMILAR CONDITIONS UNLESS NOTED OTHERWISE.

PROPOSED RESIDENCE
DENNILLE AND A.J. DECKER
468 NW HACKNEY TERRACE, LAKE CITY, FL 32055



DATE	REMARKS
03.18.13	PERMIT SET



Ken Ehlers P.E.# 10243

STRUCTURAL PLAN SERVICE INC.
COA #27152
Ken Ehlers, P.E. #10243
1834 Piccan Rd., Ocala, FL 34472
Phone (407) 236-8165
Fax (407) 236-8141
Ken Ehlers P.E.# 10243
LICENSED PROFESSIONAL ENGINEER



PLANS PREPARED BY AND UNDER THE
DIRECT SUPERVISION OF
STRUCTURAL PLAN SERVICE, INC.
AND KEN EHLERS, P.E.

PETER WOODS, RESIDENTIAL DESIGNER
1834 PICCAN RD., OCALA, FL 34472
peter.woods@pswdesign.com
(352) 675-1084

PROPOSED RESIDENCE
DENNILLE AND A.J. DECKER
468 NW HACKNEY TERRACE, LAKE CITY, FL 32055
PARCEL NO. 36-3S-16-02600-000

SHEET NUMBER

A1

PROJECT NO. 130103

PARCEL NUMBER

36-3S-16-02600-000 - COLUMBIA COUNTY, FLORIDA

SCOPE OF WORK

THIS PROJECT ENTAILS THE CONSTRUCTION OF A TWO-STORY RESIDENTIAL STRUCTURE, INCLUDING ALL REQUISITE ELECTRICAL WORK, CENTRAL AIR CONDITIONING, PLUMBING AND FIXTURES. CEILING FINISHES WILL BE GYPSUM WALLBOARD WITH TEXTURE. EXTERIOR WALL FINISHES WILL BE FACE BRICK AND CEMENT-BOARD SIDING. INTERIOR WALL FINISHES WILL BE GYPSUM WALLBOARD. ROOFING WILL BE FIBERGLASS ASPHALT SHINGLES. FLOORING AND TRIM SHALL BE PER OWNER'S SPECIFICATION.

ENGINEER'S STATEMENT

THIS PROJECT HAS BEEN DESIGNED IN ACCORDANCE WITH 2010 FLORIDA BUILDING CODE, RESIDENTIAL EDITION, SEC. R301 CRITERIA AND ASCE 7-10. TO THE BEST OF MY KNOWLEDGE THESE CONTRACT DOCUMENTS PREPARED UNDER MY DIRECT SUPERVISION COMPLY WITH THE APPLICABLE MINIMUM CODE REQUIREMENTS AND THE SAFETY STANDARDS AS DETERMINED BY THE LOCAL AUTHORITY IN ACCORDANCE WITH CHAPTERS 553 AND 633 OF THE FLORIDA STATUTES.

DISCLAIMER

THE EXISTING CONDITIONS AS SHOWN ON THIS SITE PLAN AND OTHER DRAWINGS AND DETAILS IN THIS PLAN SET ARE FROM SURVEY PLATS AND VERIFIED BY FIELD MEASUREMENTS. THE ENGINEER OF RECORD TAKES NO RESPONSIBILITY AS TO THE ACCURACY OR COMPLETENESS OF THE REPRESENTATIONS.

DESIGN CRITERIA

CONSTRUCTION TYPE: V-B
WIND SPEED = 120 MPH (3 SEC. GUST)
RISK CATEGORY = II
WIND EXPOSURE = C
INTERNAL PRESSURE COEFF. = 0.18

LIVE LOADS

ROOF = 20 PSF
FLOORS, STAIRS = 40 PSF
ATTIC, UNINHABITABLE,
WITHOUT STORAGE = 10 PSF
WITH STORAGE = 20 PSF

DESIGN WIND PRESSURES

(COMPONENTS AND CLADDING) - 120 MPH

0-10 SF = +30.4/-33.0
10-20 SF = +24.7/-26.9
20-50 SF = +23.2/-25.4
50-100 SF = +22.0/-24.2
100-500 SF = +19.3/-21.5

WALL SHEATHING FASTENING SCHEDULE

* USE 15/32" CDX OR 7/16" OSB SHEATHING (WOOD STRUCTURAL PANEL = W.S.P.)
* STANDARD EXTERIOR WALL: USE MIN. 8d HAND DRIVEN OR GUN NAILS SPACED AT EDGES AT 6" O.C. AND INTERIOR FIELD AT 12" O.C.
* EXTERIOR SHEAR WALLS: USE MIN. 8d RING-SHANK GUN NAILS AT 4" O.C. ON EDGES AND ENDS AND INTERIOR FIELD AT 6" O.C.

WEATHER PROTECTION:

A) ALL FRAMED CONSTRUCTION EXPOSED TO EXTERIOR TO HAVE A VAPOR BARRIER INSTALLED BEFORE WALL FINISH IS APPLIED.

B) ALL ROOF DECKS SHALL BE COVERED WITH APPROVED ROOF COVERINGS IN ACCORDANCE WITH CURRENT FLORIDA BUILDING CODE. ROOF ASSEMBLIES SHALL BE INSTALLED IN ACCORDANCE WITH THIS CODE AND THE APPROVED MANUFACTURER'S INSTALLATION INSTRUCTIONS SUCH THAT THE ROOF ASSEMBLY SHALL PROTECT THE BUILDING AND STRUCTURE.

C) FLASHING TO BE INSTALLED TO PREVENT MOISTURE FROM ENTERING THE WALLS AND ROOF'S THROUGH COPINGS, THROUGH MOISTURE PERMEABLE MATERIALS, AND AT INTERSECTIONS WITH PARAPET WALLS OR OTHER PENETRATIONS THROUGH ALL ROOF PLANES. USE METAL FLASHING WITH GALV. G90 28 GA. STEEL AND INSTALL AT WALL AND ROOF THROUGH JOINTS IN COPINGS, THROUGH MOISTURE PERMEABLE MATERIALS, AND AT INTERSECTIONS, WHEREVER THERE IS A CHANGE IN SLOPE OR DIRECTION AND AROUND ALL ROOF OPENINGS. ALL METAL FLASHING SHALL BE CORROSION RESISTANT AND THICKNESS TO BE NOT LESS THAN DESCRIBED IN FLORIDA BUILDING CODE TABLE R903.2.1. FLASHING NOT REQUIRED AT HIP AND RIDGE JUNCTIONS.

AREA SUMMARY

MAIN FLOOR CONDITIONED AREA	2357 S.F.
UPPER FLOOR CONDITIONED AREA	1662 S.F.
TOTAL CONDITIONED AREA	4019 S.F.
GARAGE AND STORAGE AREA	899 S.F.
VERANDA AND GAZEBO AREA	821 S.F.
ENTRY AREA	131 S.F.
TOTAL NON-CONDITIONED AREA	1851 S.F.
TOTAL AREA	5870 S.F.

GENERAL FRAMING NOTES


* ALL LUMBER TO SOUTHERN YELLOW PINE No. 2 OR SPRUCE-PINE-FIR No. 2, MAXIMUM MOISTURE CONTENT OF 19 %. EXTERIOR LUMBER AND LUMBER IN CONTACT WITH CONCRETE TO BE PRESSURE-TREATED.

* EXTERIOR WINDOWS AND GLASS DOORS MUST MEET THE REQUIREMENTS OF R-613-1 OF THE FLORIDA RESIDENTIAL BUILDING CODE 2010 EDITION.
R-613-1 EXTERIOR WINDOWS AND GLASS DOORS
R-613.1.1 TESTING AND LABELING. EXTERIOR WINDOWS AND GLASS DOORS SHALL BE TESTED BY AN APPROVED INDEPENDENT TESTING LABORATORY AND BEAR AN AAMA OR WDMA OR OTHER APPROVED LABEL IDENTIFYING THE MANUFACTURER, PERFORMANCE CHARACTERISTICS, AND APPROVED PRODUCT EVALUATION ENTITY TO INDICATE COMPLIANCE WITH THE REQUIREMENTS OF THE FOLLOWING SPECIFICATION: WINDOWS - ANSI/AAMA/NW-101/S2 OR 1S2/NAFS OR AAMA/WDMA/CSA 101/1S2/A440 OR TAS202 (HVHZ SHALL COMPLY WITH TAS-202 UTILIZING ASTM).

SHEET INDEX

A1	PROJECT DATA, GENERAL NOTES, DESIGN CRITERIA
A2	MAIN FLOOR PLAN
A3	UPPER FLOOR PLAN
A4	ROOF PLAN
A5	EXTERIOR ELEVATIONS
A6	EXTERIOR ELEVATIONS
E1	MAIN FLOOR ELECTRICAL PLAN
E2	UPPER FLOOR ELECTRICAL PLAN
S1	FOUNDATION PLAN
S2	FLOOR FRAMING PLAN, LOWER ROOF FRAMING PLAN
S3	UPPER ROOF FRAMING PLAN
S4	SECTIONS AND DETAILS
S5	SECTIONS AND DETAILS
S6	SECTIONS AND DETAILS

AN BY OTHERS

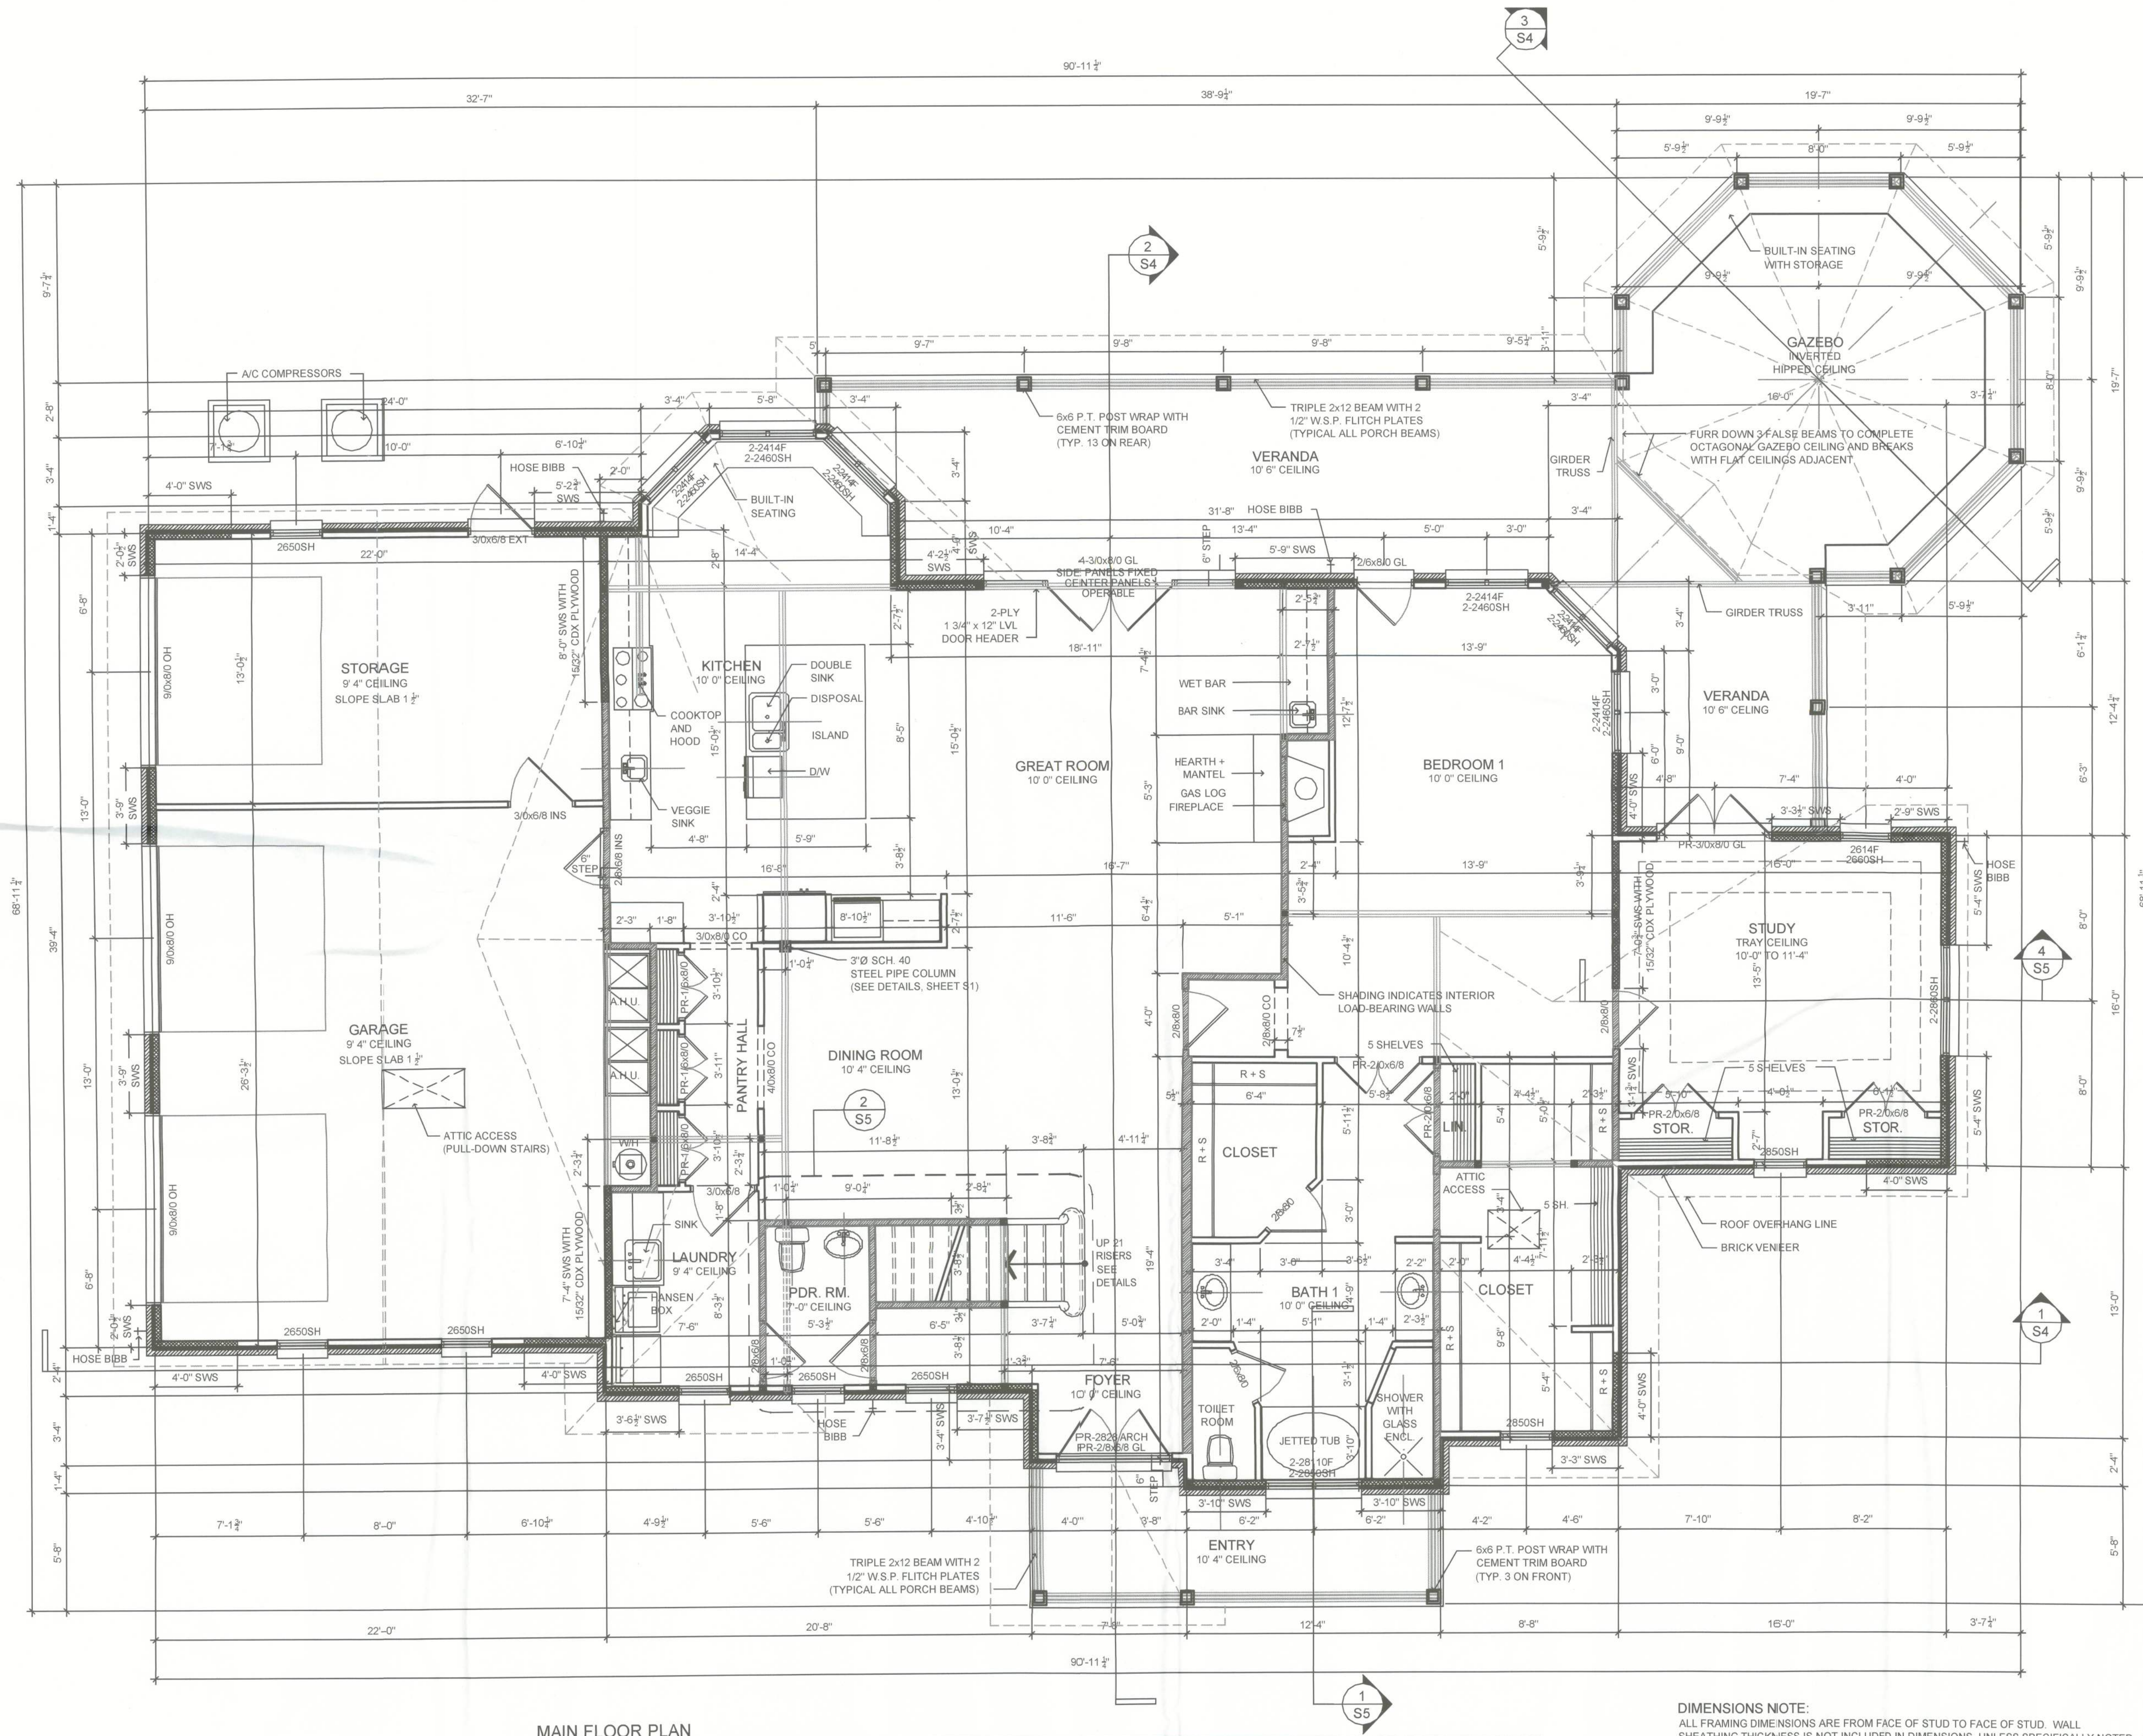

MAIN FLOOR PLAN

INTERIOR AND EXTERIOR SHEARWALL SEGMENTS INDICATED WITH RESPECTIVE EFFECTIVE LENGTHS.
SHEARWALLS SHALL BE CONSTRUCTED WITH HOLD-DOWN HARDWARE PER DETAILS SHOWN ON STRUCTURAL DRAWINGS.
SHEARWALL SHEATHING SHALL BE 1/2" W.S.P. NAILED WITH 8d RING-SHANK GUN NAILS AT 4" O.C. ON EDGES AND ENDS AND 6" O.C. IN FIELD.

SCALE: 1/4" = 1' 0"

DIMENSIONS NOTE:
ALL FRAMING DIMENSIONS ARE FROM FACE OF STUD TO FACE OF STUD. WALL SHEATHING THICKNESS IS NOT INCLUDED IN DIMENSIONS, UNLESS SPECIFICALLY NOTED.

STRUCTURAL NOTE:
INTERIOR 4x4 AND 4x6 POSTS (BOTH P.T. AND ENGINEERED WOOD) ARE INDICATED ON THIS PLAN FOR REFERENCE. SEE FOUNDATION PLAN AND FLOOR FRAMING PLAN FOR CALL OUTS OF POST AND REQUIRED STRAPPING AND ANCHORAGE.

DATE	REMARKS
03.16.13	PERMIT SET

A. Ebers
3/15/13
Ken Ebers P.E.# 18243

STRUCTURAL PLAN SERVICE INC.
CO. #27152
Post Office Box 940128
Maitland, FL 32794
Phone (407) 296-8156
Fax (407) 296-8156
Ken Ebers P.E.# 18243
LICENSED PROFESSIONAL ENGINEER


SPS

PLANS PREPARED BY AND UNDER THE
DIRECT SUPERVISION OF
STRUCTURAL PLAN SERVICE, INC.
AND KEN EBERS, P.E.

PETER WOODS, RESIDENTIAL DESIGNER
8508 PECAN RD., OCALA, FL 34742
peter.woods@redesigngroup.com
(352) 675-4884

PROPOSED RESIDENCE
DENNILLE AND A.J. DECKER
468 NW HACKNEY TERRACE, LAKE CITY, FL 32055
PARCEL NO. 36-3S-16-02600-000

SHEET NUMBER
A2
PROJECT NO. 130103

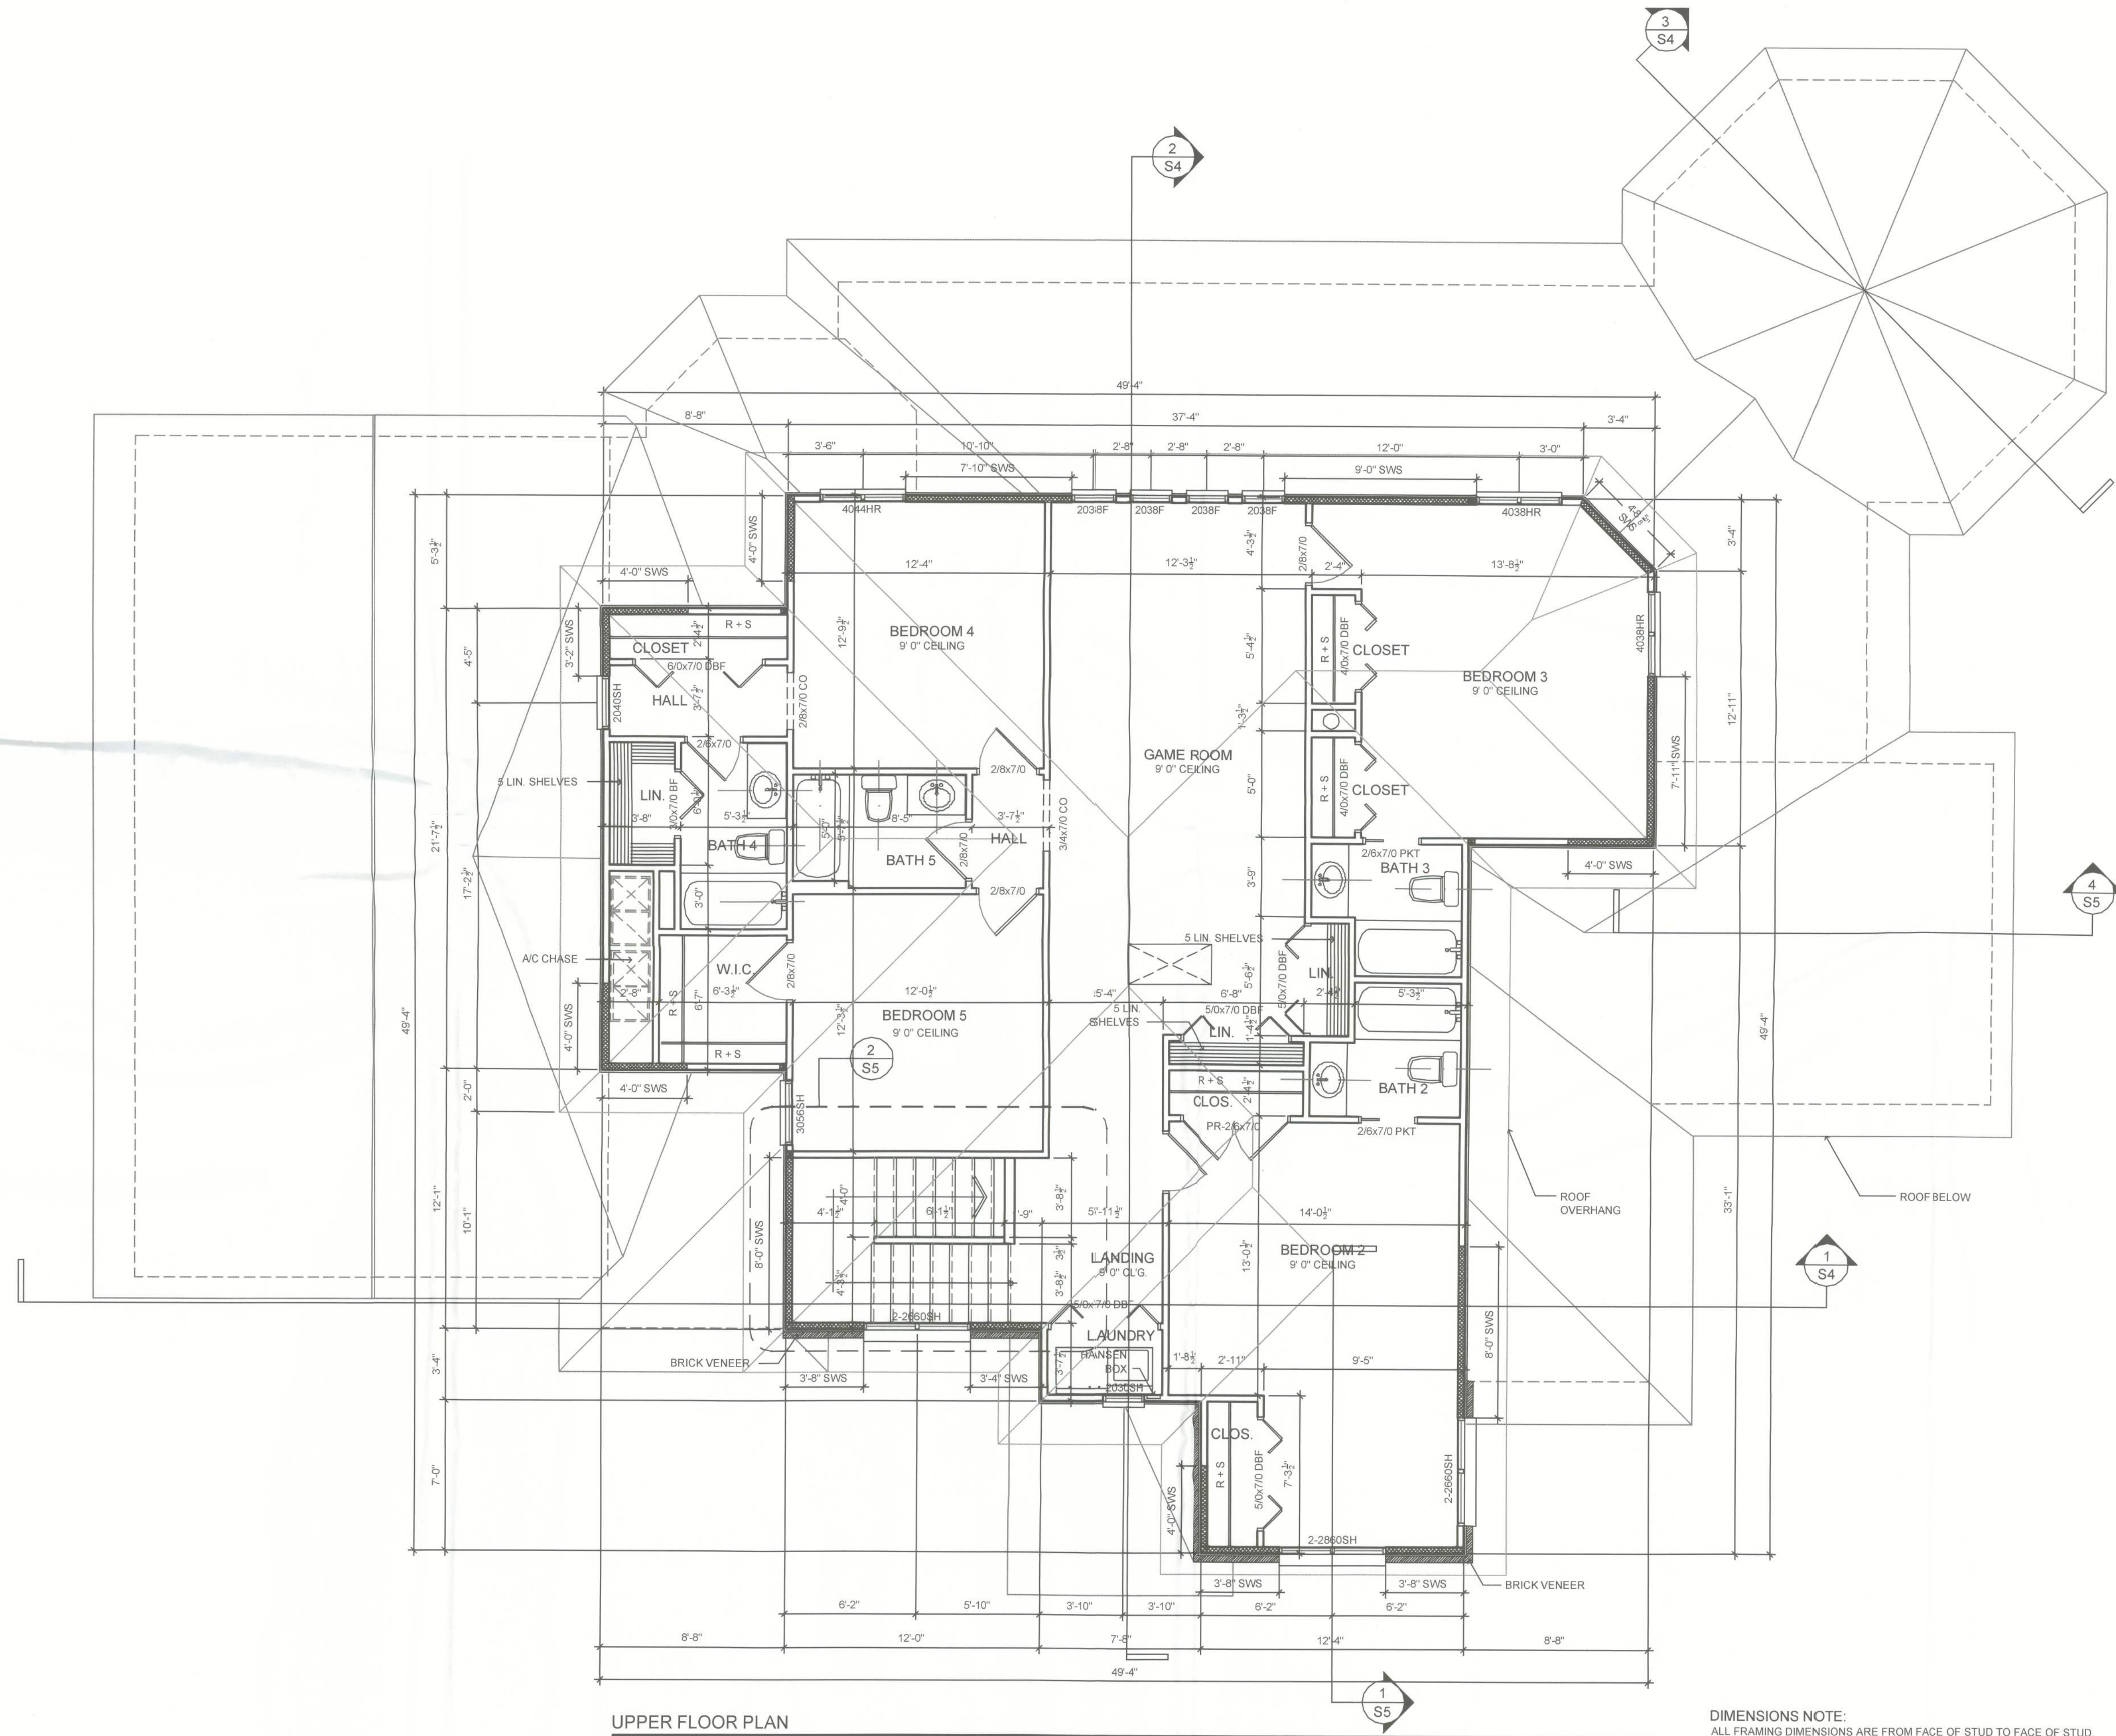

UPPER FLOOR PLAN

INTERIOR AND EXTERIOR SHEARWALL SEGMENTS INDICATED WITH RESPECTIVE EFFECTIVE LENGTHS.
SHEARWALLS SHALL BE CONSTRUCTED WITH HOLD-DOWN HARDWARE PER DETAILS SHOWN ON STRUCTURAL DRAWINGS.
SHEARWALL SHEATHING SHALL BE 1/2" W.S.P. NAILED WITH 8d RING-SHANK GUN NAILS AT 4" O.C. ON EDGES AND ENDS AND 6" O.C. IN FIELD.

SCALE: 1/4" = 1'-0"

DIMENSIONS NOTE:
ALL FRAMING DIMENSIONS ARE FROM FACE OF STUD TO FACE OF STUD.
WALL SHEATHING THICKNESS IS NOT INCLUDED IN DIMENSIONS, UNLESS SPECIFICALLY NOTED.

DATE	REMARKS
03.18.13	PERMIT SET

Ken Ehlers P.E.# 18243
2/15/13

STRUCTURAL PLAN SERVICE INC.
COA #27152
Office: 840128
Mobile: 840128
Phone: (407) 295-8155
Fax: (407) 295-8141
Ken Ehlers P.E.# 18243
LICENSED PROFESSIONAL ENGINEER


PLANS PREPARED BY AND UNDER THE
DIRECT SUPERVISION OF
STRUCTURAL PLAN SERVICE, INC.
AND KEN EHLERS, P.E.

PETER WOODS, RESIDENTIAL DESIGNER
1884 PECAN RD., OCALA, FL 34712
peter.woods@residentialdesign.com
(352) 675-0884



PROPOSED RESIDENCE
DENNILLE AND A.J. DECKER
468 NW HACKNEY TERRACE, LAKE CITY, FL 32055
PARCEL NO. 36-3S-16-02600-000

SHEET NUMBER
A3

PROJECT NO. 130103

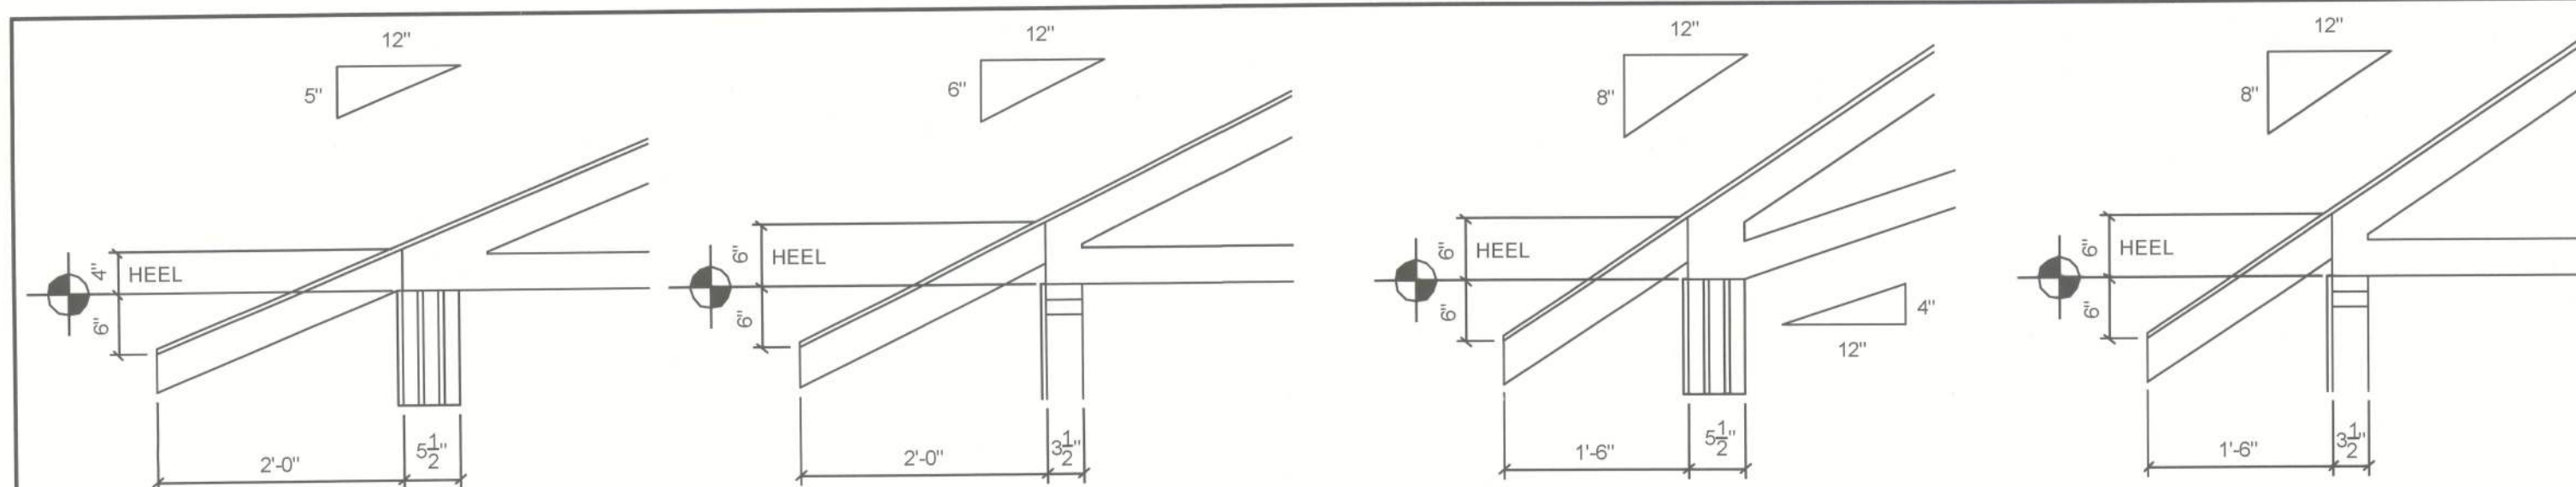

VERANDA ROOF
TRUSS HEEL HEIGHT DETAILS

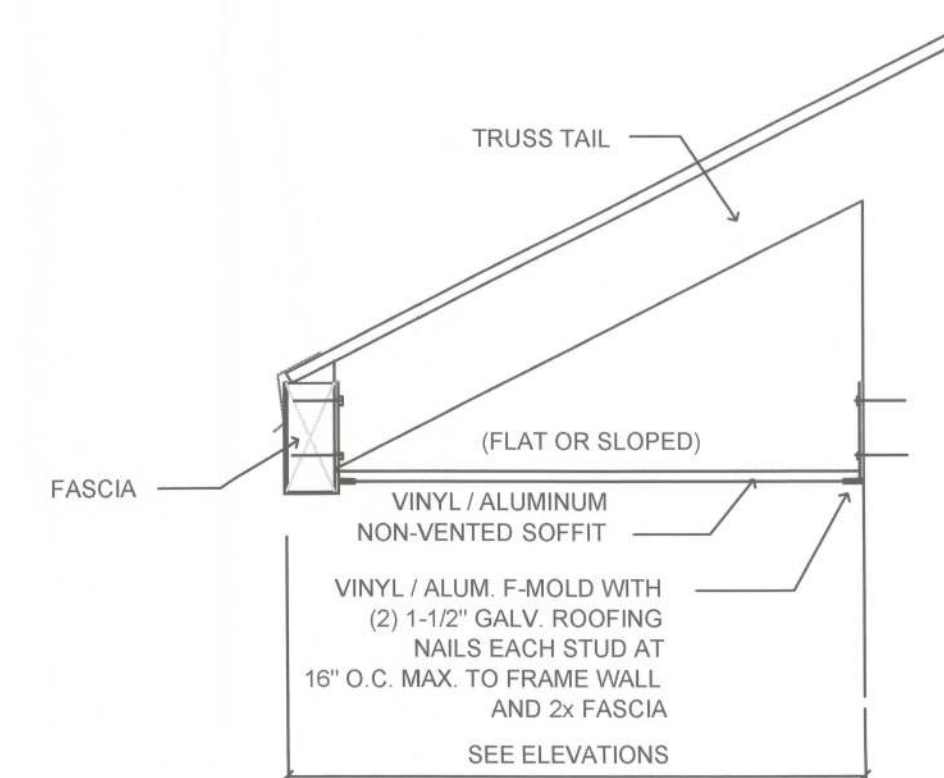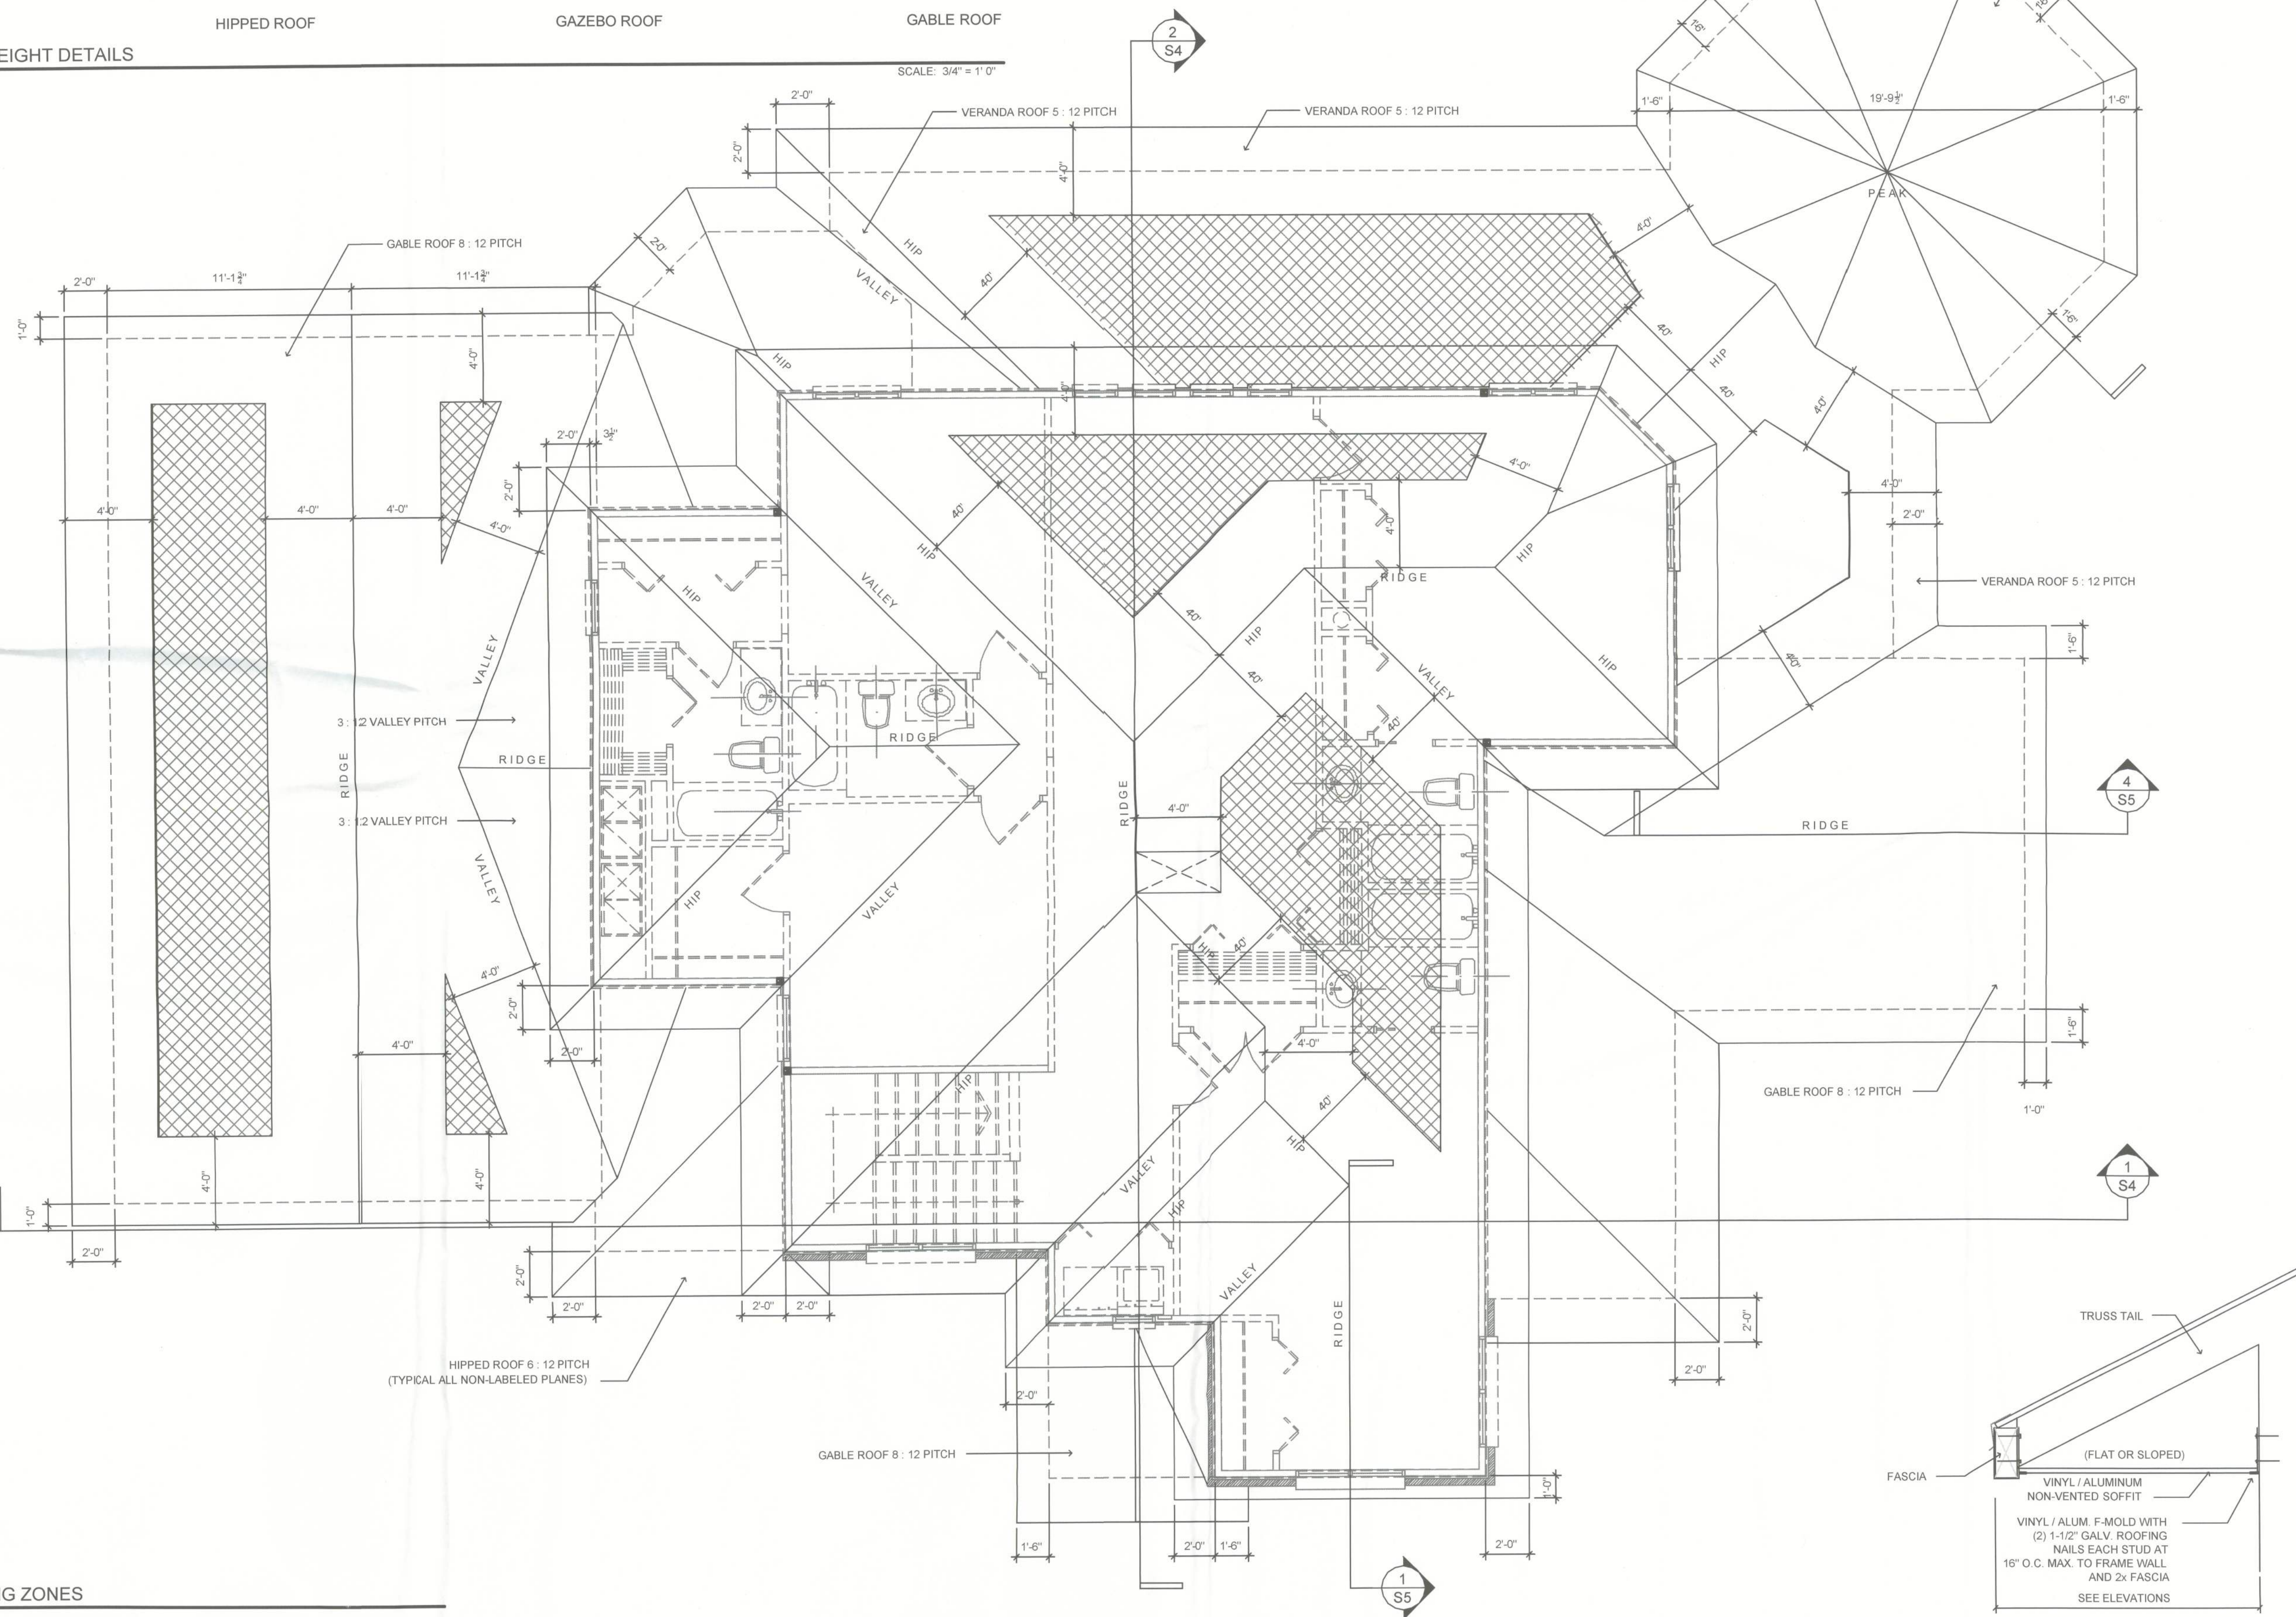

SOFFIT CONNECTION DETAIL

NOT TO SCALE

TRUSS NAILING ZONES

NON-SHADED AREAS
8d RING SHANK GUN NAILS AT 4" O.C. ON EDGES AND 6" O.C. IN FIELD

SHADED AREAS
8d RING SHANK GUN NAILS AT 6" O.C. ON EDGES AND 6" O.C. IN FIELD

ROOF PLAN

SCALE: 1/4" = 1' 0"

DATE	REMARKS
03.18.13	PERMIT SET

Handwritten: + Glen 3/18/13
Ken Ehlers P.E. # 18243

STRUCTURAL PLAN SERVICE INC.
COA #27152 Box 840128
Kissimmee, FL 33764
Phone (407) 295-8155
Fax (407) 295-8141
Ken Ehlers P.E. # 18243
LICENSED PROFESSIONAL ENGINEER

SPS

PLANS PREPARED BY AND UNDER THE
DIRECT SUPERVISION OF
STRUCTURAL PLAN SERVICE, INC.
AND KEN EHLERS, P.E.

PETER WOODS, RESIDENTIAL DESIGNER
8888 PECAN RD., OCALA, FL 34772
peter.woods@robertsongroup.com
(352) 573-0894

PROPOSED RESIDENCE
DENNILLE AND A.J. DECKER
468 NW HACKNEY TERRACE, LAKE CITY, FL 32055
PARCEL NO. 36-3S-16-02600-000

SHEET NUMBER
A4
PROJECT NO. 130103



REAR ELEVATION

SCALE: 1/4" = 1' 0"



FRONT ELEVATION

SCALE: 1/4" = 1' 0"

DATE	REMARKS
03.18.13	PERMIT SET

Ken Ehlers P.E. # 18243
3/18/13


STRUCTURAL PLAN SERVICE INC.
COA #27152
Post Office Box 940128
Metairie, LA 70009-0128
Tel (504) 885-6155
Fax (504) 885-6141
Ken Ehlers P.E. # 18243
LICENSED PROFESSIONAL ENGINEER

PLANS PREPARED BY AND UNDER THE
DIRECT SUPERVISION OF
STRUCTURAL PLAN SERVICE INC.
AND KEN EHLERS, P.E.

PETER WOODS, RESIDENTIAL DESIGNER
6004 PECAN RD., OCALA, FL 34472
peter.woods@woodsgroup.com
(352) 578-4884


PROPOSED RESIDENCE
DENNILLE AND A.J. DECKER
468 NW HACKNEY TERRACE, LAKE CITY, FL 32055
PARCEL NO. 36-3S-16-02600-000

SHEET NUMBER
A5
PROJECT NO. 130103

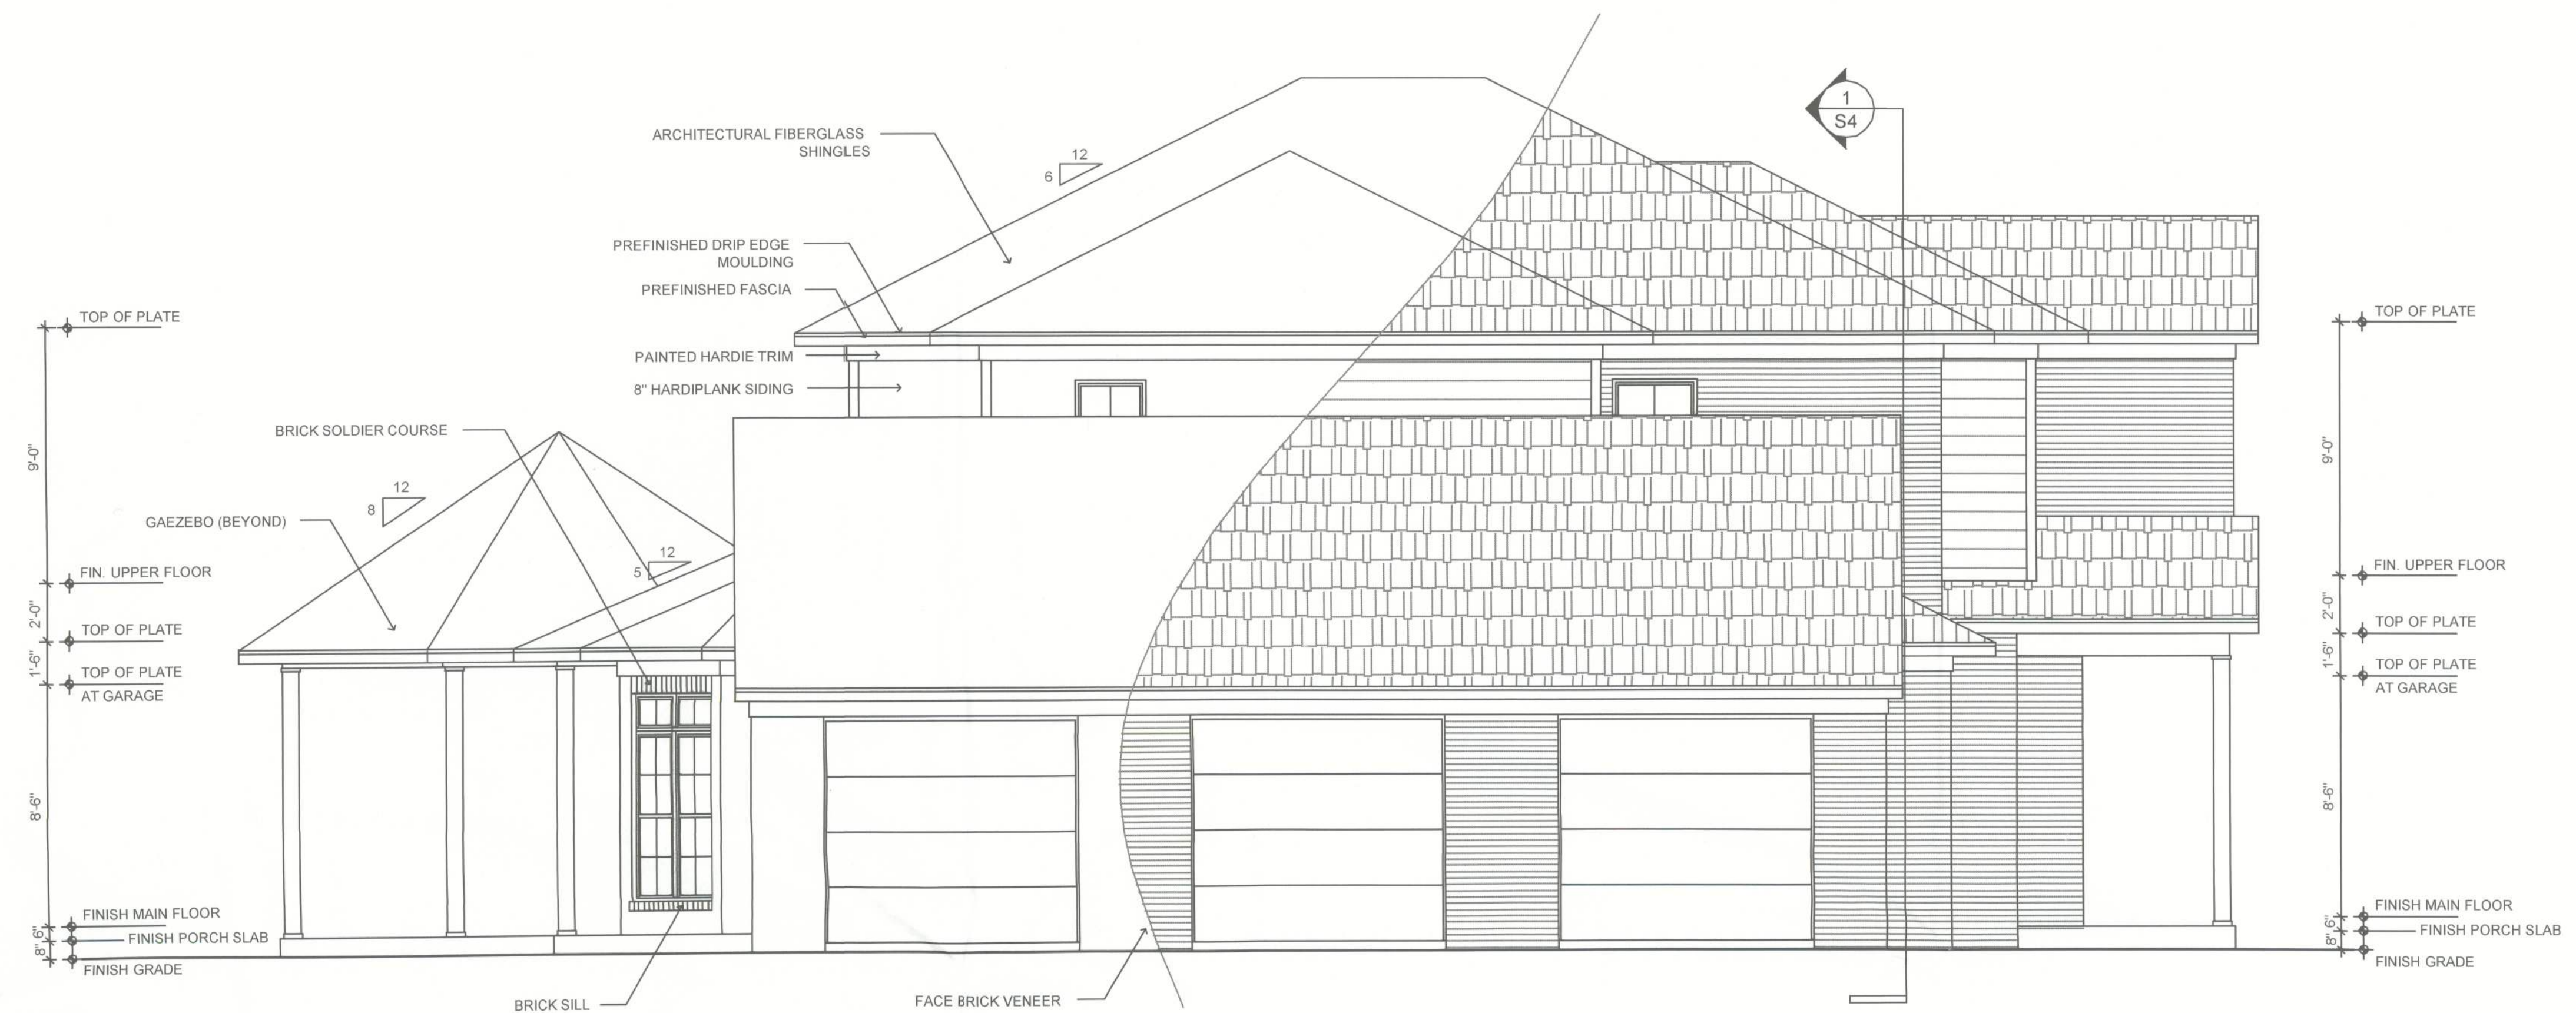

LEFT ELEVATION

SCALE: 1/4" = 1' 0"

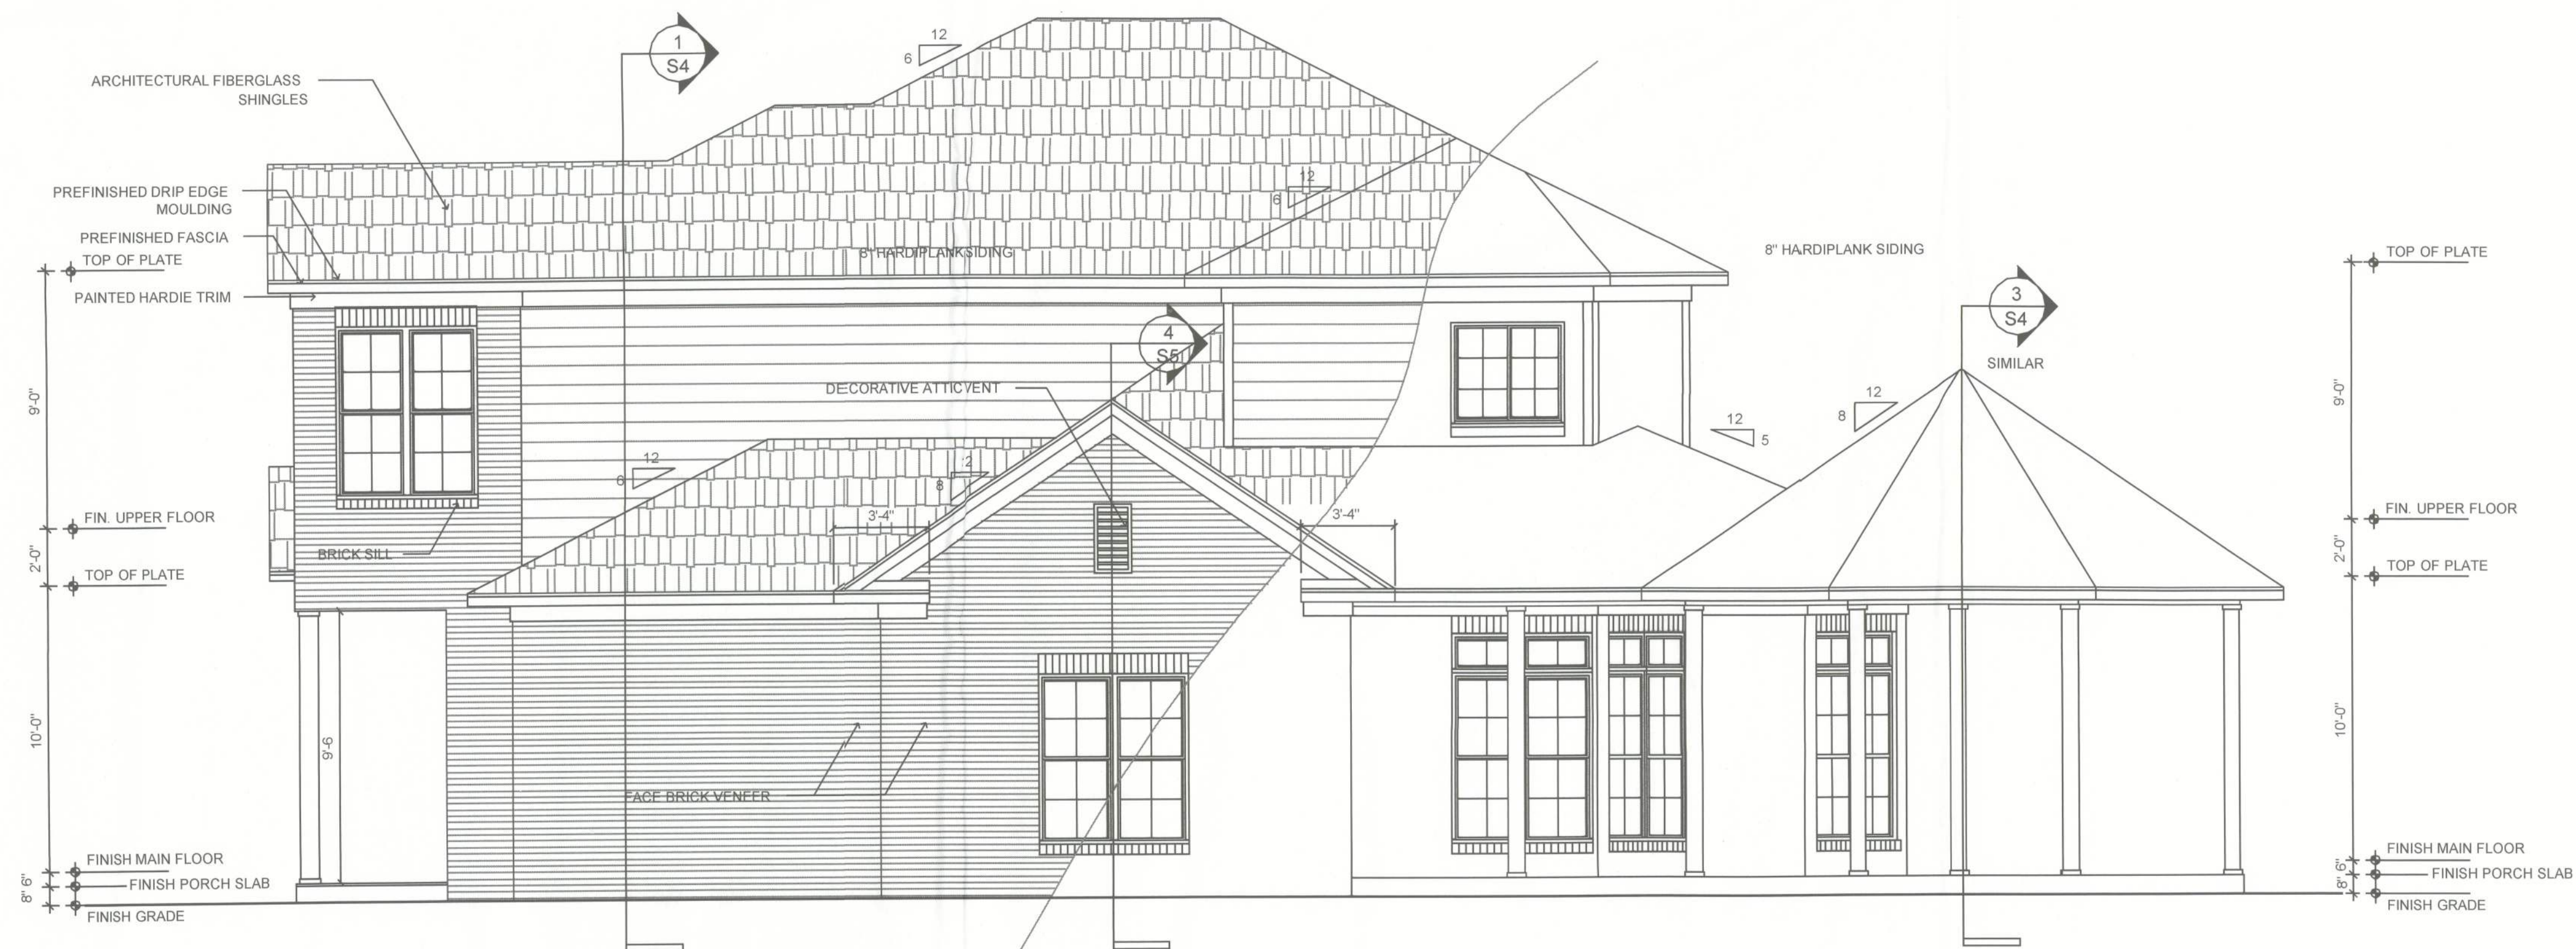

RIGHT ELEVATION

SCALE: 1/4" = 1' 0"

DATE	REMARKS
02.18.13	PERMIT SET

Ken Ehlers P.E.# 19243
3/18/13


STRUCTURAL PLAN SERVICE INC.
COA #27152
Post. Office Box 940128
Baltimore, MD 21294-0155
Tel (410) 728-8155
Fax (410) 285-8141
Ken Ehlers P.E.# 19243
LICENSED PROFESSIONAL ENGINEER

PLANS PREPARED BY AND UNDER THE
DIRECT SUPERVISION OF
STRUCTURAL PLAN SERVICE, INC.
AND KEN EHLERS, P.E.

PETER WOODS, RESIDENTIAL DESIGNER
6524 PISCANA RD., OCALA, FL 34472
peter.woods@structuralplanservice.com
(882) 875-4804

PROPOSED RESIDENCE
DENNILE AND A.J. DECKER
468 NW HACKNEY TERRACE, LAKE CITY, FL 32055
PARCEL NO. 36-3S-16-02600-000

SHEET NUMBER
A6
PROJECT NO. 130103

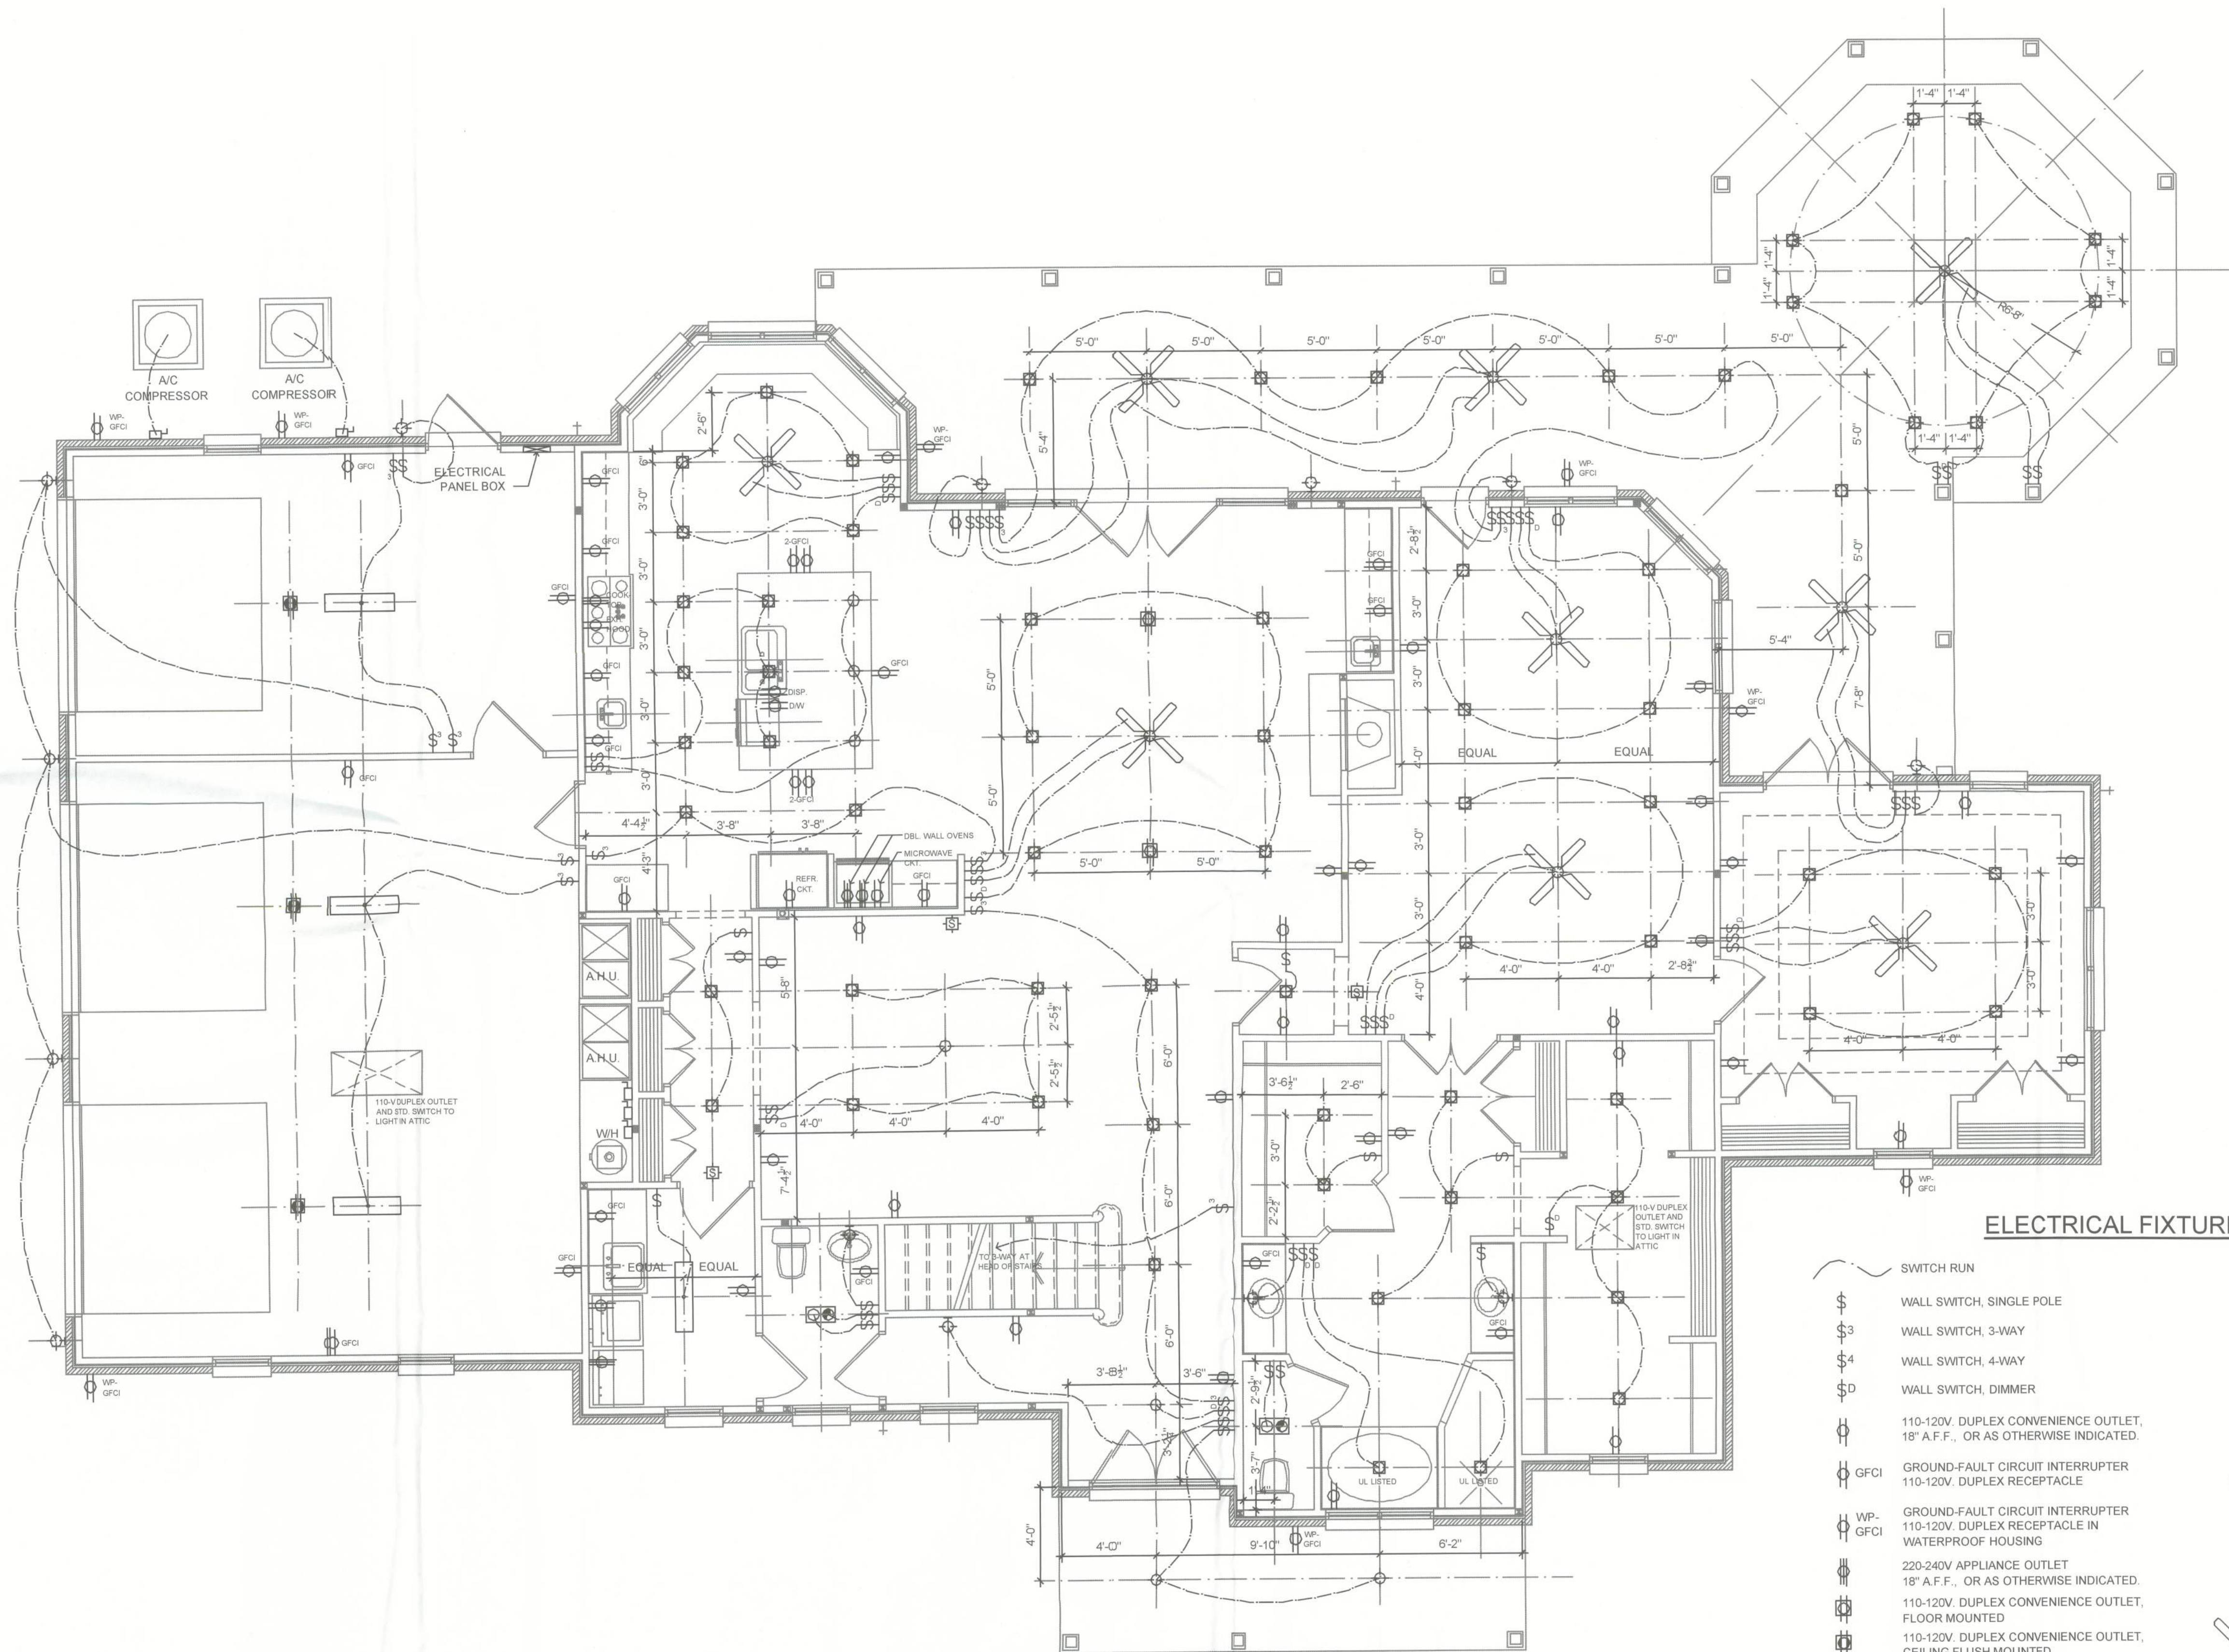

MAIN FLOOR ELECTRICAL PLAN

ALL RECEPTACLES, LIGHTING, AND SAFETY PROTECTION DEVICES (I.E. SMOKE DETECTORS, CARBON MONOXIDE DETECTORS, ETC.) SHALL BE ON CIRCUITRY PROTECTED BY A U.L.-LISTED ARC-FAULT CIRCUIT INTERRUPTER (EXCEPT IN LAUNDRY, KITCHEN, BATHS, GARAGE AND PORCHES).

ALL RECEPTACLES SHALL BE U.L.-LISTED TAMPER-RESISTANT AND OUTDOOR GFCI RECEPTACLES SHALL BE WEATHER-RESISTANT.

PROVIDE SMOKE DETECTORS IN ALL SLEEPING ROOMS AND WITHIN THE IMMEDIATE VICINITY OF SLEEPING ROOMS AND CARBON MONOXIDE DETECTORS WITHIN 10 FEET OF ALL SLEEPING ROOMS.

ALL SMOKE DETECTORS ARE TO HAVE BATTERY BACK-UP AND BE HARD-WIRED AND INTERCONNECTED SO THAT IN THE EVENT THAT ONE IS ACTIVATED, ALL ARE ACTIVATED.

ELECTRICAL FIXTURE LEGEND

- | | |
|--|---|
| SWITCH RUN | MEDIA OUTLET, FLOOR MOUNTED |
| WALL SWITCH, SINGLE POLE | MEDIA OUTLET, 18" A.F.F., OR AS OTHERWISE INDICATED |
| WALL SWITCH, 3-WAY | TELEPHONE OUTLET, 18" A.F.F., OR AS OTHERWISE INDICATED |
| WALL SWITCH, 4-WAY | DOUBLE ADJUSTABLE FLOOD LIGHT |
| WALL SWITCH, DIMMER | INSTANTANEOUS WATER HEATER |
| 110-120V. DUPLEX CONVENIENCE OUTLET, 18" A.F.F., OR AS OTHERWISE INDICATED | COMBO FAN/LIGHT |
| GROUND-FAULT CIRCUIT INTERRUPTER 110-120V. DUPLEX RECEPTACLE | CEILING LIGHT SURFACE MOUNTED, 150W. MAX. |
| GROUND-FAULT CIRCUIT INTERRUPTER 110-120V. DUPLEX RECEPTACLE IN WATERPROOF HOUSING | CEILING LIGHT RECESS MOUNTED, 150W. MAX. |
| 220-240V APPLIANCE OUTLET 18" A.F.F., OR AS OTHERWISE INDICATED | COMBO SMOKE / CARBON MONOXIDE ALARM HARD-WIRED & INTERCONNECTED |
| 110-120V. DUPLEX CONVENIENCE OUTLET, FLOOR MOUNTED | CEILING FAN WITH LIGHT KIT |
| 110-120V. DUPLEX CONVENIENCE OUTLET, CEILING FLUSH MOUNTED | 4-LAMP FLUORESCENT WITH ACRYLIC LENS SURFACE MOUNT |
| POWER SWITCH / DISCONNECT | LED ROPE LIGHT (INDIRECT) |
| WALL LIGHT / SCONCE SURFACE MOUNTED, 150W. MAX. | |
| COACH LIGHT SURFACE MOUNTED, 150W. MAX. | |

DATE	REMARKS
02.18.13	PERMIT SET

Ken Ehlers P.E. # 18243

3/18/13

STRUCTURAL PLAN SERVICE INC.
COA #27152
Post Office Box 940128
Metairie, LA 70004-0128
Phone (504) 885-8166
Fax (504) 885-8141
Ken Ehlers P.E. # 18243
LICENSED PROFESSIONAL ENGINEER

SPS


PLANS PREPARED BY AND UNDER THE DIRECT SUPERVISION OF STRUCTURAL PLAN SERVICE, INC. AND KEN EHLERS, P.E.

PETER WOODS, RESIDENTIAL DESIGNER
1824 PECAN RD., OCALA, FL 34472
peter.woods@psdesigngroup.com
(352) 575-4884

PROPOSED RESIDENCE
DENNILLE AND A.J. DECKER
468 NW HACKNEY TERRACE, LAKE CITY, FL 32055
PARCEL NO. 36-3S-16-02600-000

SHEET NUMBER
E1

PROJECT NO. 130103

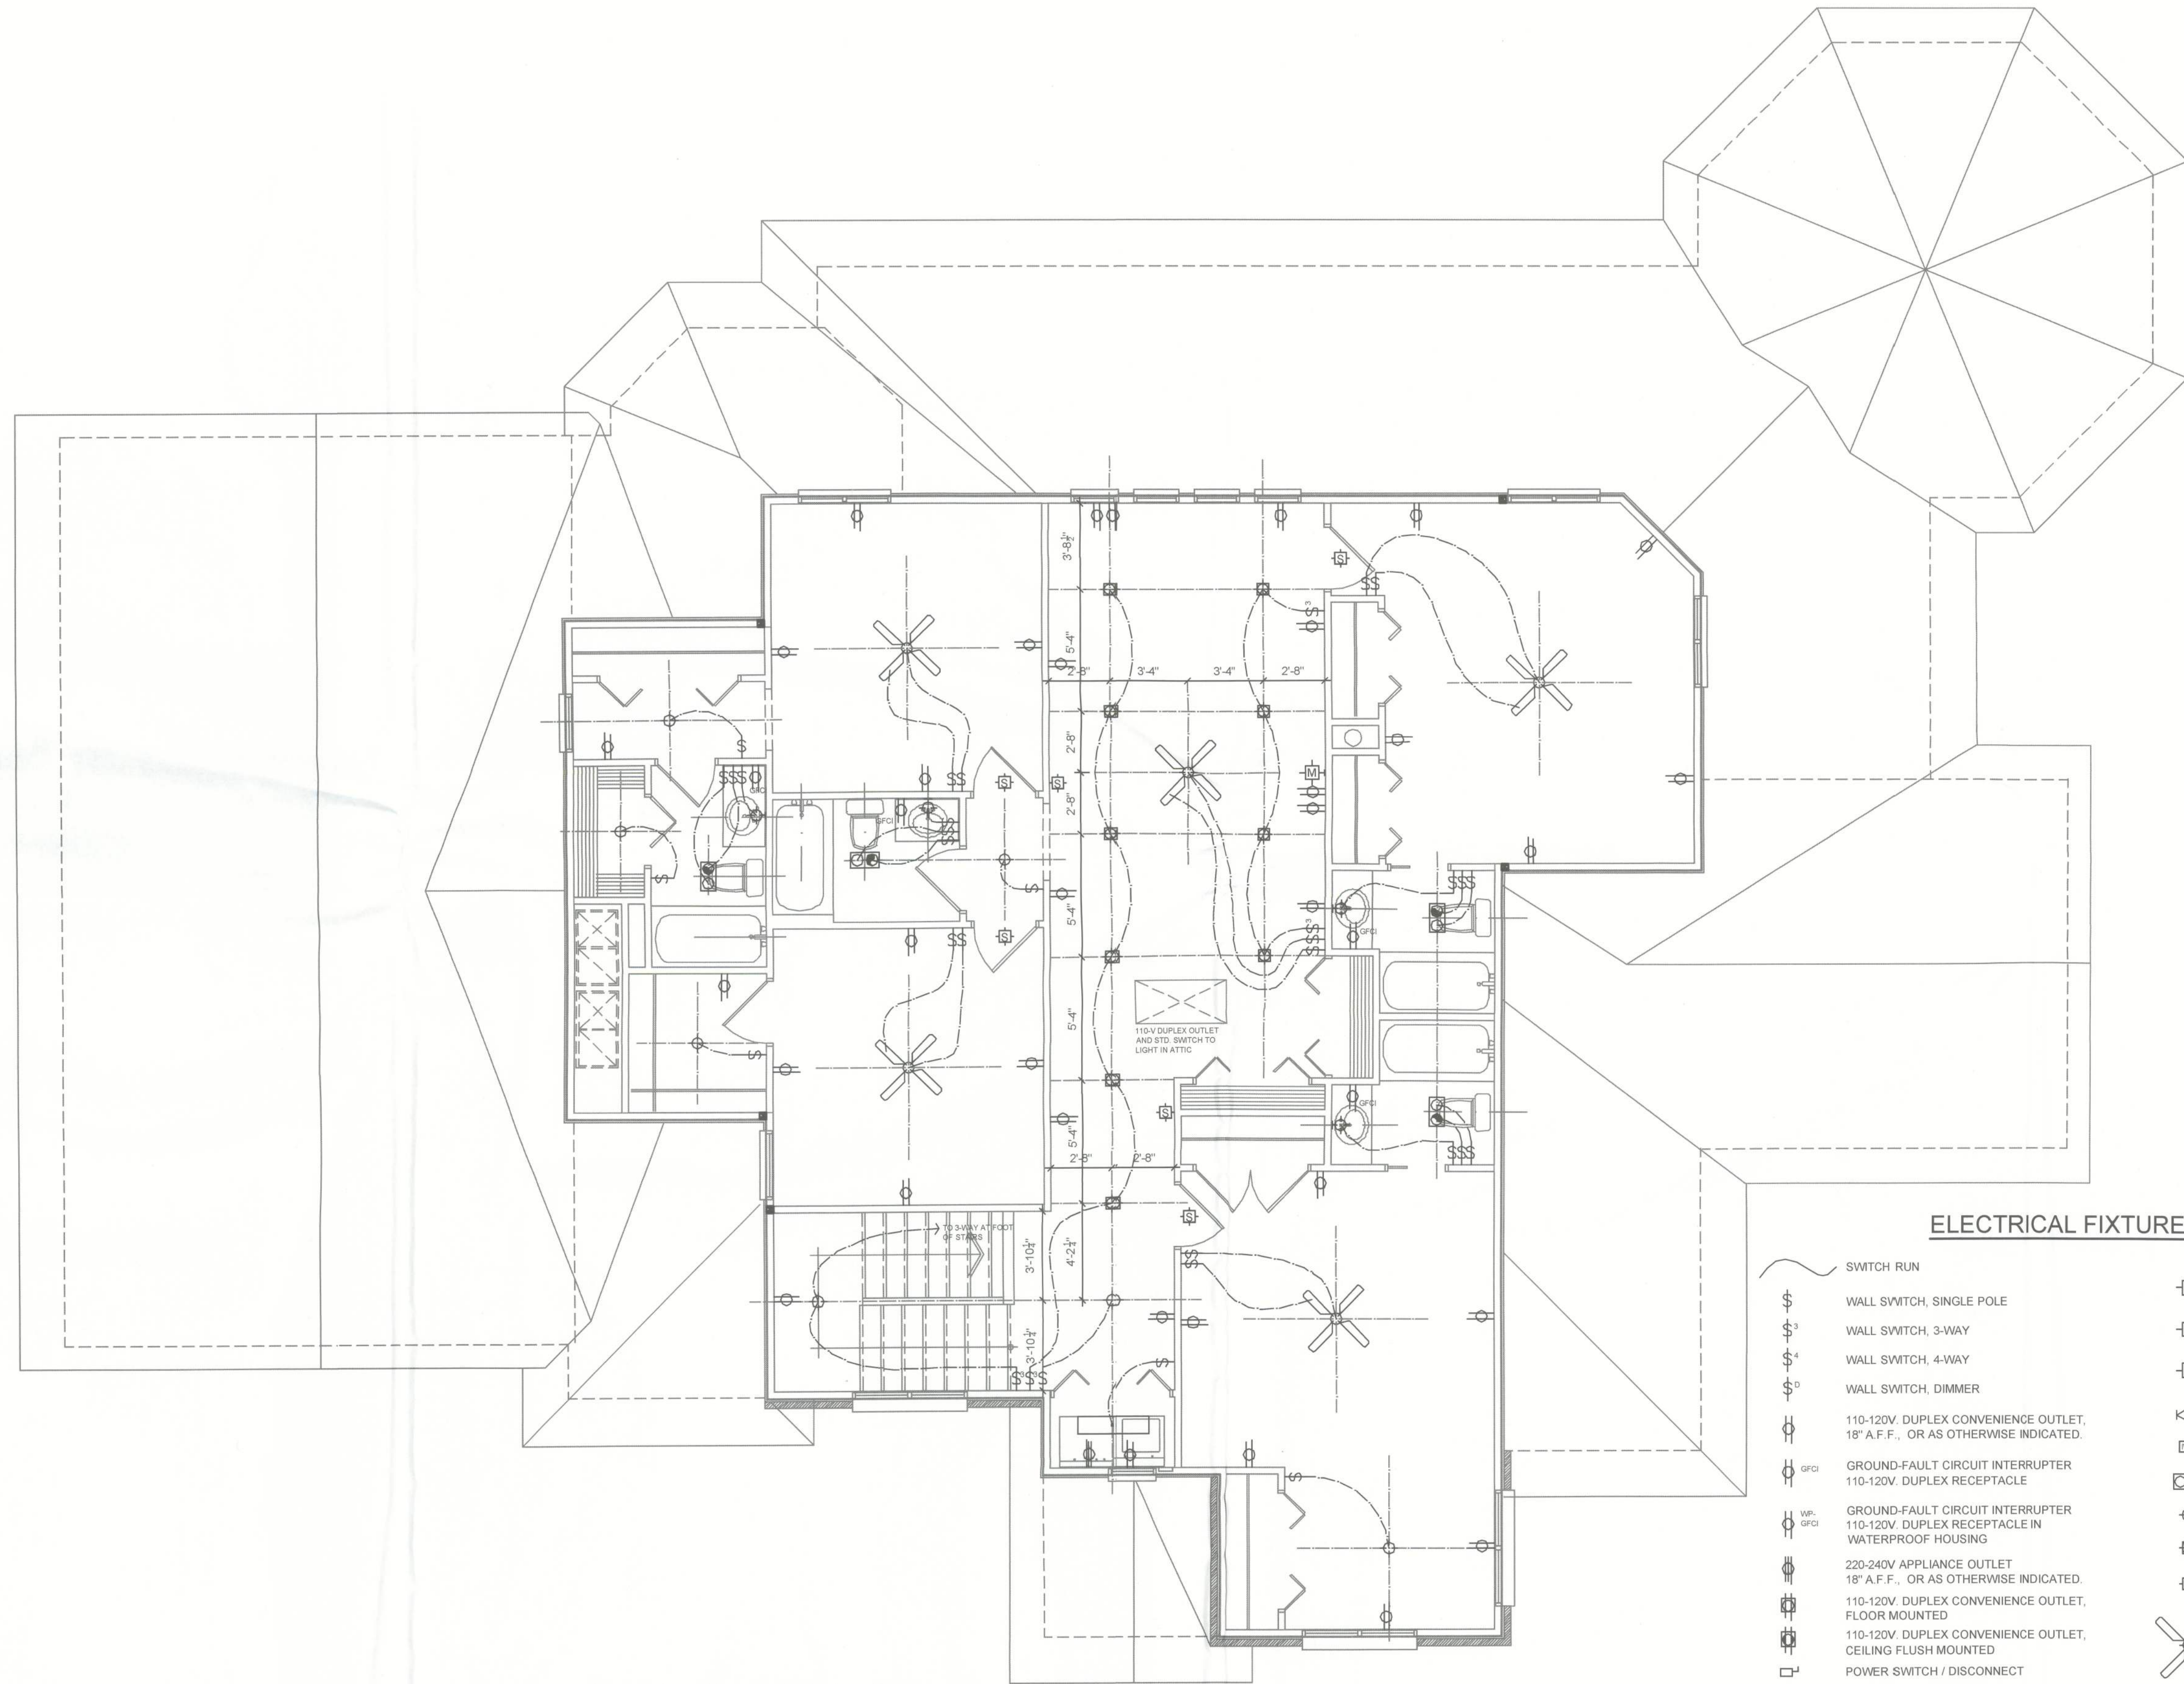

UPPER FLOOR ELECTRICAL PLAN

SCALE: 1/4" = 1' 0"

ALL RECEPTACLES, LIGHTING, AND SAFETY PROTECTION DEVICES (I.E. SMOKE DETECTORS, CARBON MONOXIDE DETECTORS, ETC.) SHALL BE ON CIRCUITRY PROTECTED BY A U.L.-LISTED ARC-FAULT CIRCUIT INTERRUPTER (EXCEPT IN LAUNDRY, KITCHEN, BATHS, GARAGE AND PORCHES).

ALL RECEPTACLES SHALL BE U.L.-LISTED TAMPER-RESISTANT AND OUTDOOR GFCI RECEPTACLES SHALL BE WEATHER-RESISTANT.

PROVIDE SMOKE DETECTORS IN ALL SLEEPING ROOMS AND WITHIN THE IMMEDIATE VICINITY OF SLEEPING ROOMS AND CARBON MONOXIDE DETECTORS WITHIN 10 FEET OF ALL SLEEPING ROOMS.

ALL SMOKE DETECTORS ARE TO HAVE BATTERY BACK-UP AND BE HARD-WIRED AND INTERCONNECTED SO THAT IN THE EVENT THAT ONE IS ACTIVATED, ALL ARE ACTIVATED.

ELECTRICAL FIXTURE LEGEND

- | | |
|--|---|
| SWITCH RUN | MEDIA OUTLET, FLOOR MOUNTED |
| WALL SWITCH, SINGLE POLE | MEDIA OUTLET, 18" A.F.F., OR AS OTHERWISE INDICATED |
| WALL SWITCH, 3-WAY | TELEPHONE OUTLET, 18" A.F.F., OR AS OTHERWISE INDICATED |
| WALL SWITCH, 4-WAY | DOUBLE ADJUSTABLE FLOOD LIGHT |
| WALL SWITCH, DIMMER | INSTANTANEOUS WATER HEATER |
| 110-120V. DUPLEX CONVENIENCE OUTLET, 18" A.F.F., OR AS OTHERWISE INDICATED. | COMBO FAN/LIGHT |
| GROUND-FAULT CIRCUIT INTERRUPTER 110-120V. DUPLEX RECEPTACLE | CEILING LIGHT, SURFACE MOUNTED, 150W. MAX. |
| GROUND-FAULT CIRCUIT INTERRUPTER 110-120V. DUPLEX RECEPTACLE IN WATERPROOF HOUSING | CEILING LIGHT, RECESS MOUNTED, 150W. MAX. |
| 220-240V APPLIANCE OUTLET 110-120V. DUPLEX CONVENIENCE OUTLET, FLOOR MOUNTED | COMBO SMOKE / CARBON MONOXIDE ALARM HARD-WIRED & INTERCONNECTED |
| 110-120V. DUPLEX CONVENIENCE OUTLET, CEILING FLUSH MOUNTED | CEILING FAN WITH LIGHT KIT |
| POWER SWITCH / DISCONNECT | 4-LAMP FLUORESCENT WITH ACRYLIC LENS SURFACE MOUNT |
| WALL LIGHT / SCONCE SURFACE MOUNTED, 150W. MAX. | LED ROPE LIGHT (INDIRECT) |
| COACH LIGHT SURFACE MOUNTED, 150W. MAX. | |

DATE	REMARKS
03.18.13	PERMIT SET

K. Ehlers
3/18/13
Ken Ehlers P.E.# 18243






STRUCTURAL PLAN SERVICE INC.
C/OA #27162
Post Office Box 940128
Maitland, FL 32764
Phone (407) 296-6166
Fax (407) 296-6166
Ken Ehlers P.E.# 18243
LICENSED PROFESSIONAL ENGINEER

PLANS PREPARED BY AND UNDER THE DIRECT SUPERVISION OF
STRUCTURAL PLAN SERVICE INC.
AND KEN EHLERS, P.E.

PETER WOODS, RESIDENTIAL DESIGNER
6801 PECAN RD., OCALA, FL 3472
peter.woods@residentialdesign.com
(352) 575-4884

PROPOSED RESIDENCE
DENNILLE AND A.J. DECKER
468 NW HACKNEY TERRACE, LAKE CITY, FL 32055
PARCEL NO. 36-3S-16-02600-000

SHEET NUMBER
E2
PROJECT NO. 130103

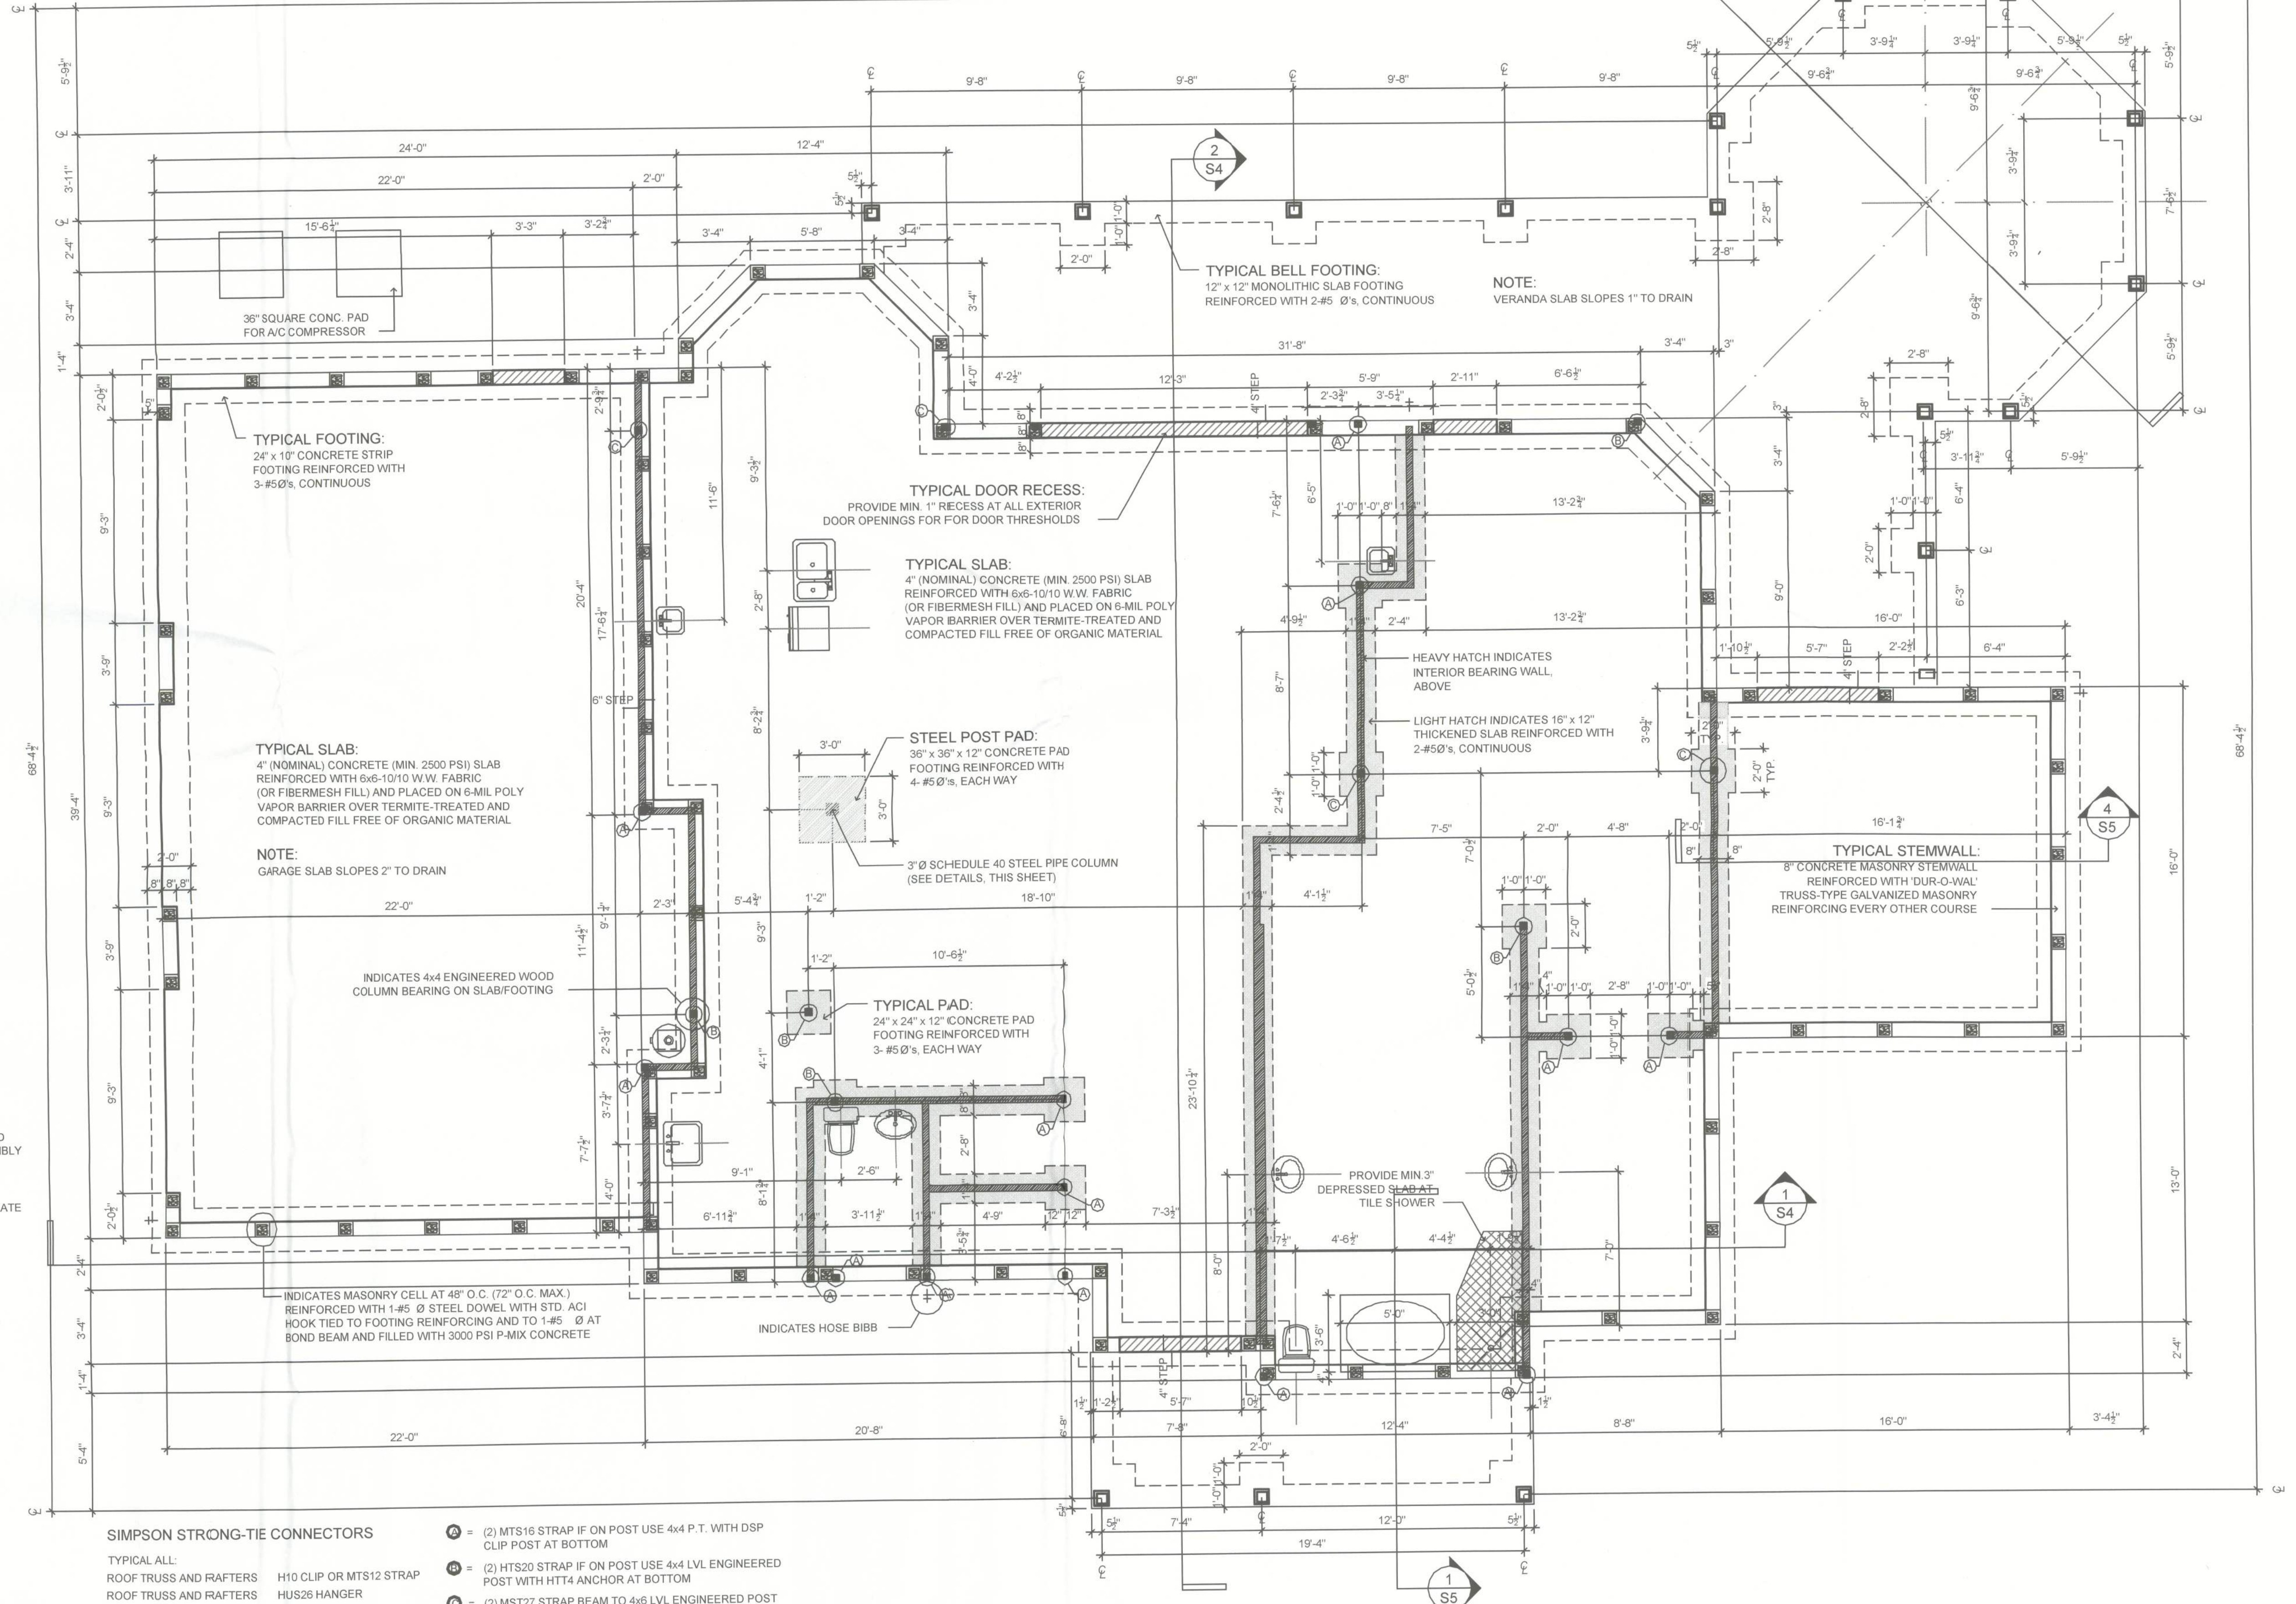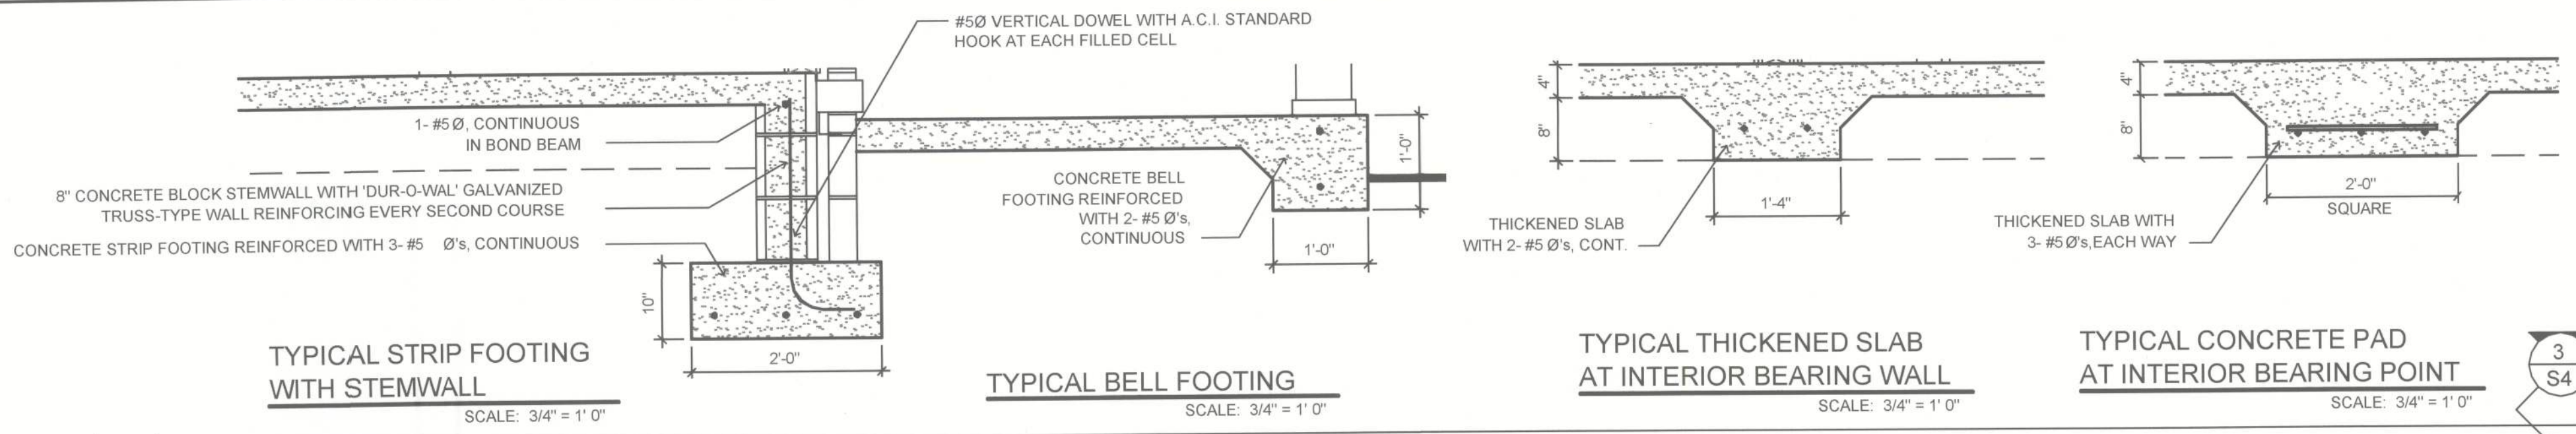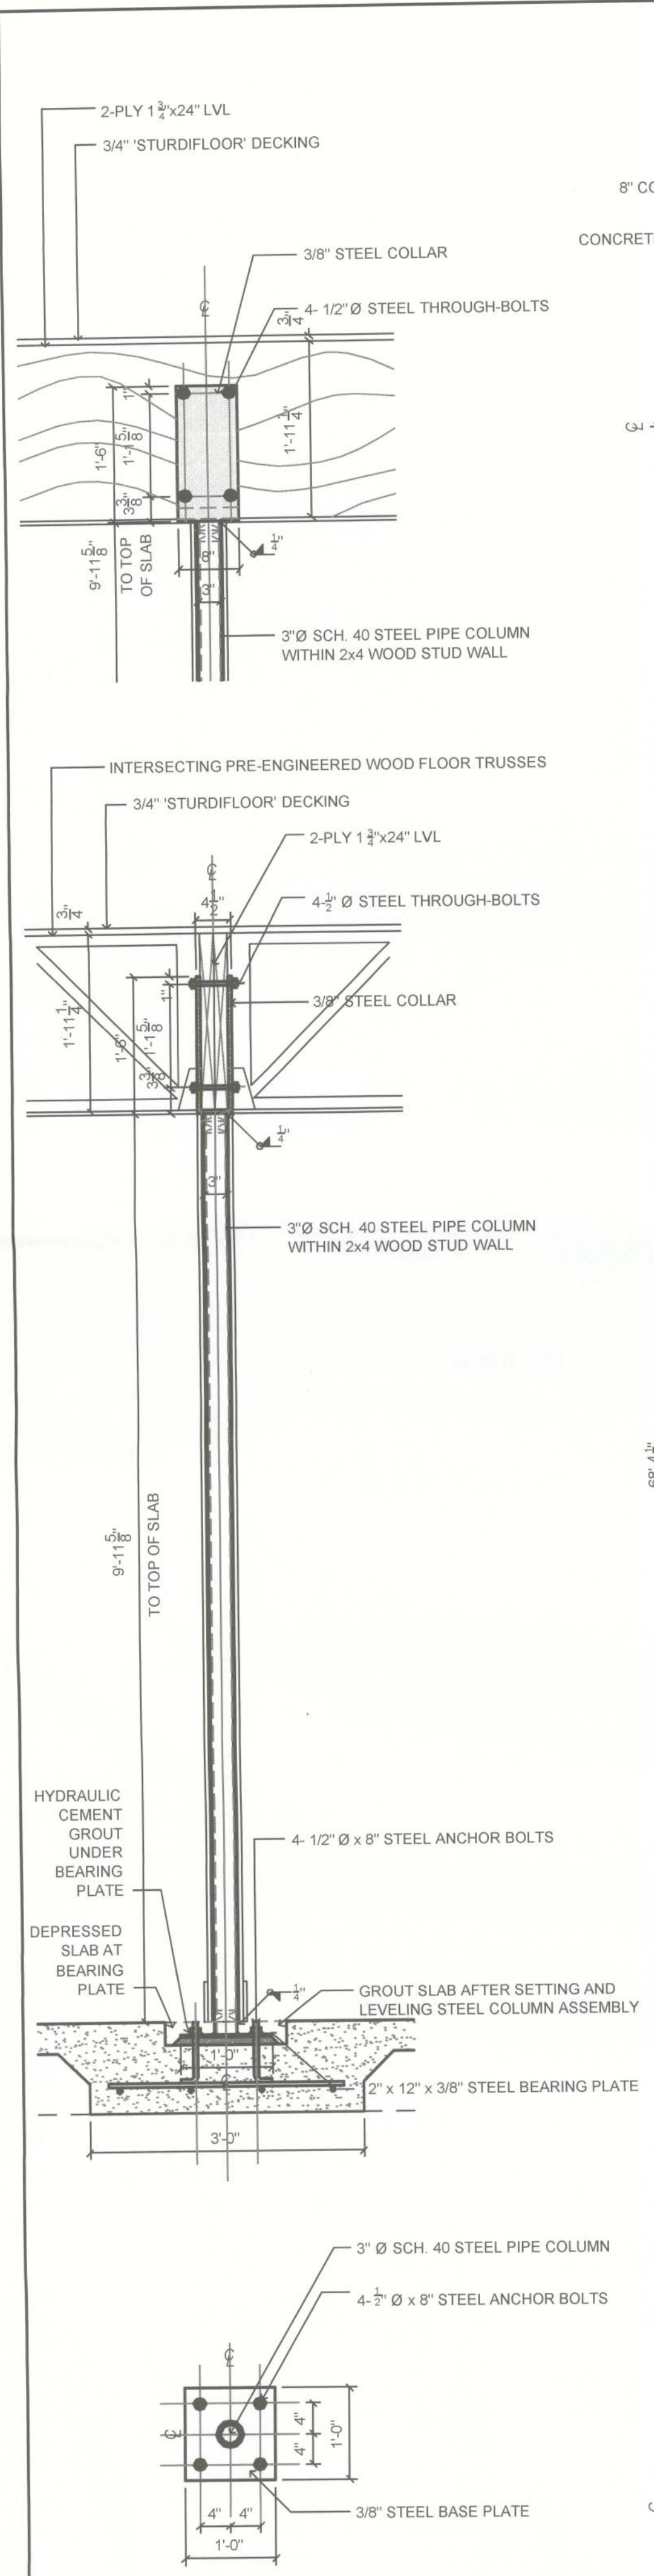

- SIMPSON STRONG-TIE CONNECTORS**
- TYPICAL ALL:
ROOF TRUSS AND RAFTERS H10 CLIP OR MTS12 STRAP
ROOF TRUSS AND RAFTERS HUS26 HANGER
ROOF GIRDERS HHUS28-2 HANGER
FLOOR TRUSSES HUS412 HANGER
FLOOR BEAMS HGUS412 HANGER
(UNLESS NOTED OTHERWISE ON PLANS)
- Ⓐ = (2) MTS16 STRAP IF ON POST USE 4x4 P.T. WITH DSP CLIP POST AT BOTTOM
Ⓑ = (2) HTS20 STRAP IF ON POST USE 4x4 LVL ENGINEERED POST WITH HTT4 ANCHOR AT BOTTOM
Ⓒ = (2) MTS27 STRAP BEAM TO 4x6 LVL ENGINEERED POST WITH HTT5 ANCHOR AT BOTTOM
Ⓓ = (1) MGT ANCHOR GIRDER WITH 5/8" ALL-THREAD ROD TO INVERTED HTT4 ON 4x4 P.T. POST, THEN ADD (1) MTS60 STRAP OVER FLOORS TO LVL ENGINEERED POST ON FIRST FLOOR WITH HTT5 ANCHOR BOTTOM

FOUNDATION PLAN
ADDITIONAL FOUNDATION DETAILS SHEET S6

DATE	REMARKS
03.18.13	PERMIT SET

Ken Ehlers P.E.# 10243

STRUCTURAL PLAN SERVICE INC.
COA #27152
Post Office Box 940128
Miami, FL 33165
Phone (407) 295-8165
Fax (407) 295-8141
Ken Ehlers P.E.# 10243
LICENSED PROFESSIONAL ENGINEER


PLANS PREPARED BY AND UNDER THE
DIRECT SUPERVISION OF
STRUCTURAL PLAN SERVICE INC.
AND KEN EHLERS, P.E.

PETER WOODS, RESIDENTIAL DESIGNER
1824 PECAN RD., OCALA, FL 34772
peterwoods@peterwoods.com
(352) 975-4884

PROPOSED RESIDENCE
DENNILLE AND A.J. DECKER
468 NW HACKNEY TERRACE, LAKE CITY, FL 32055
PARCEL NO. 36-3S-16-02600-000

SHEET NUMBER
S1
PROJECT NO. 130103



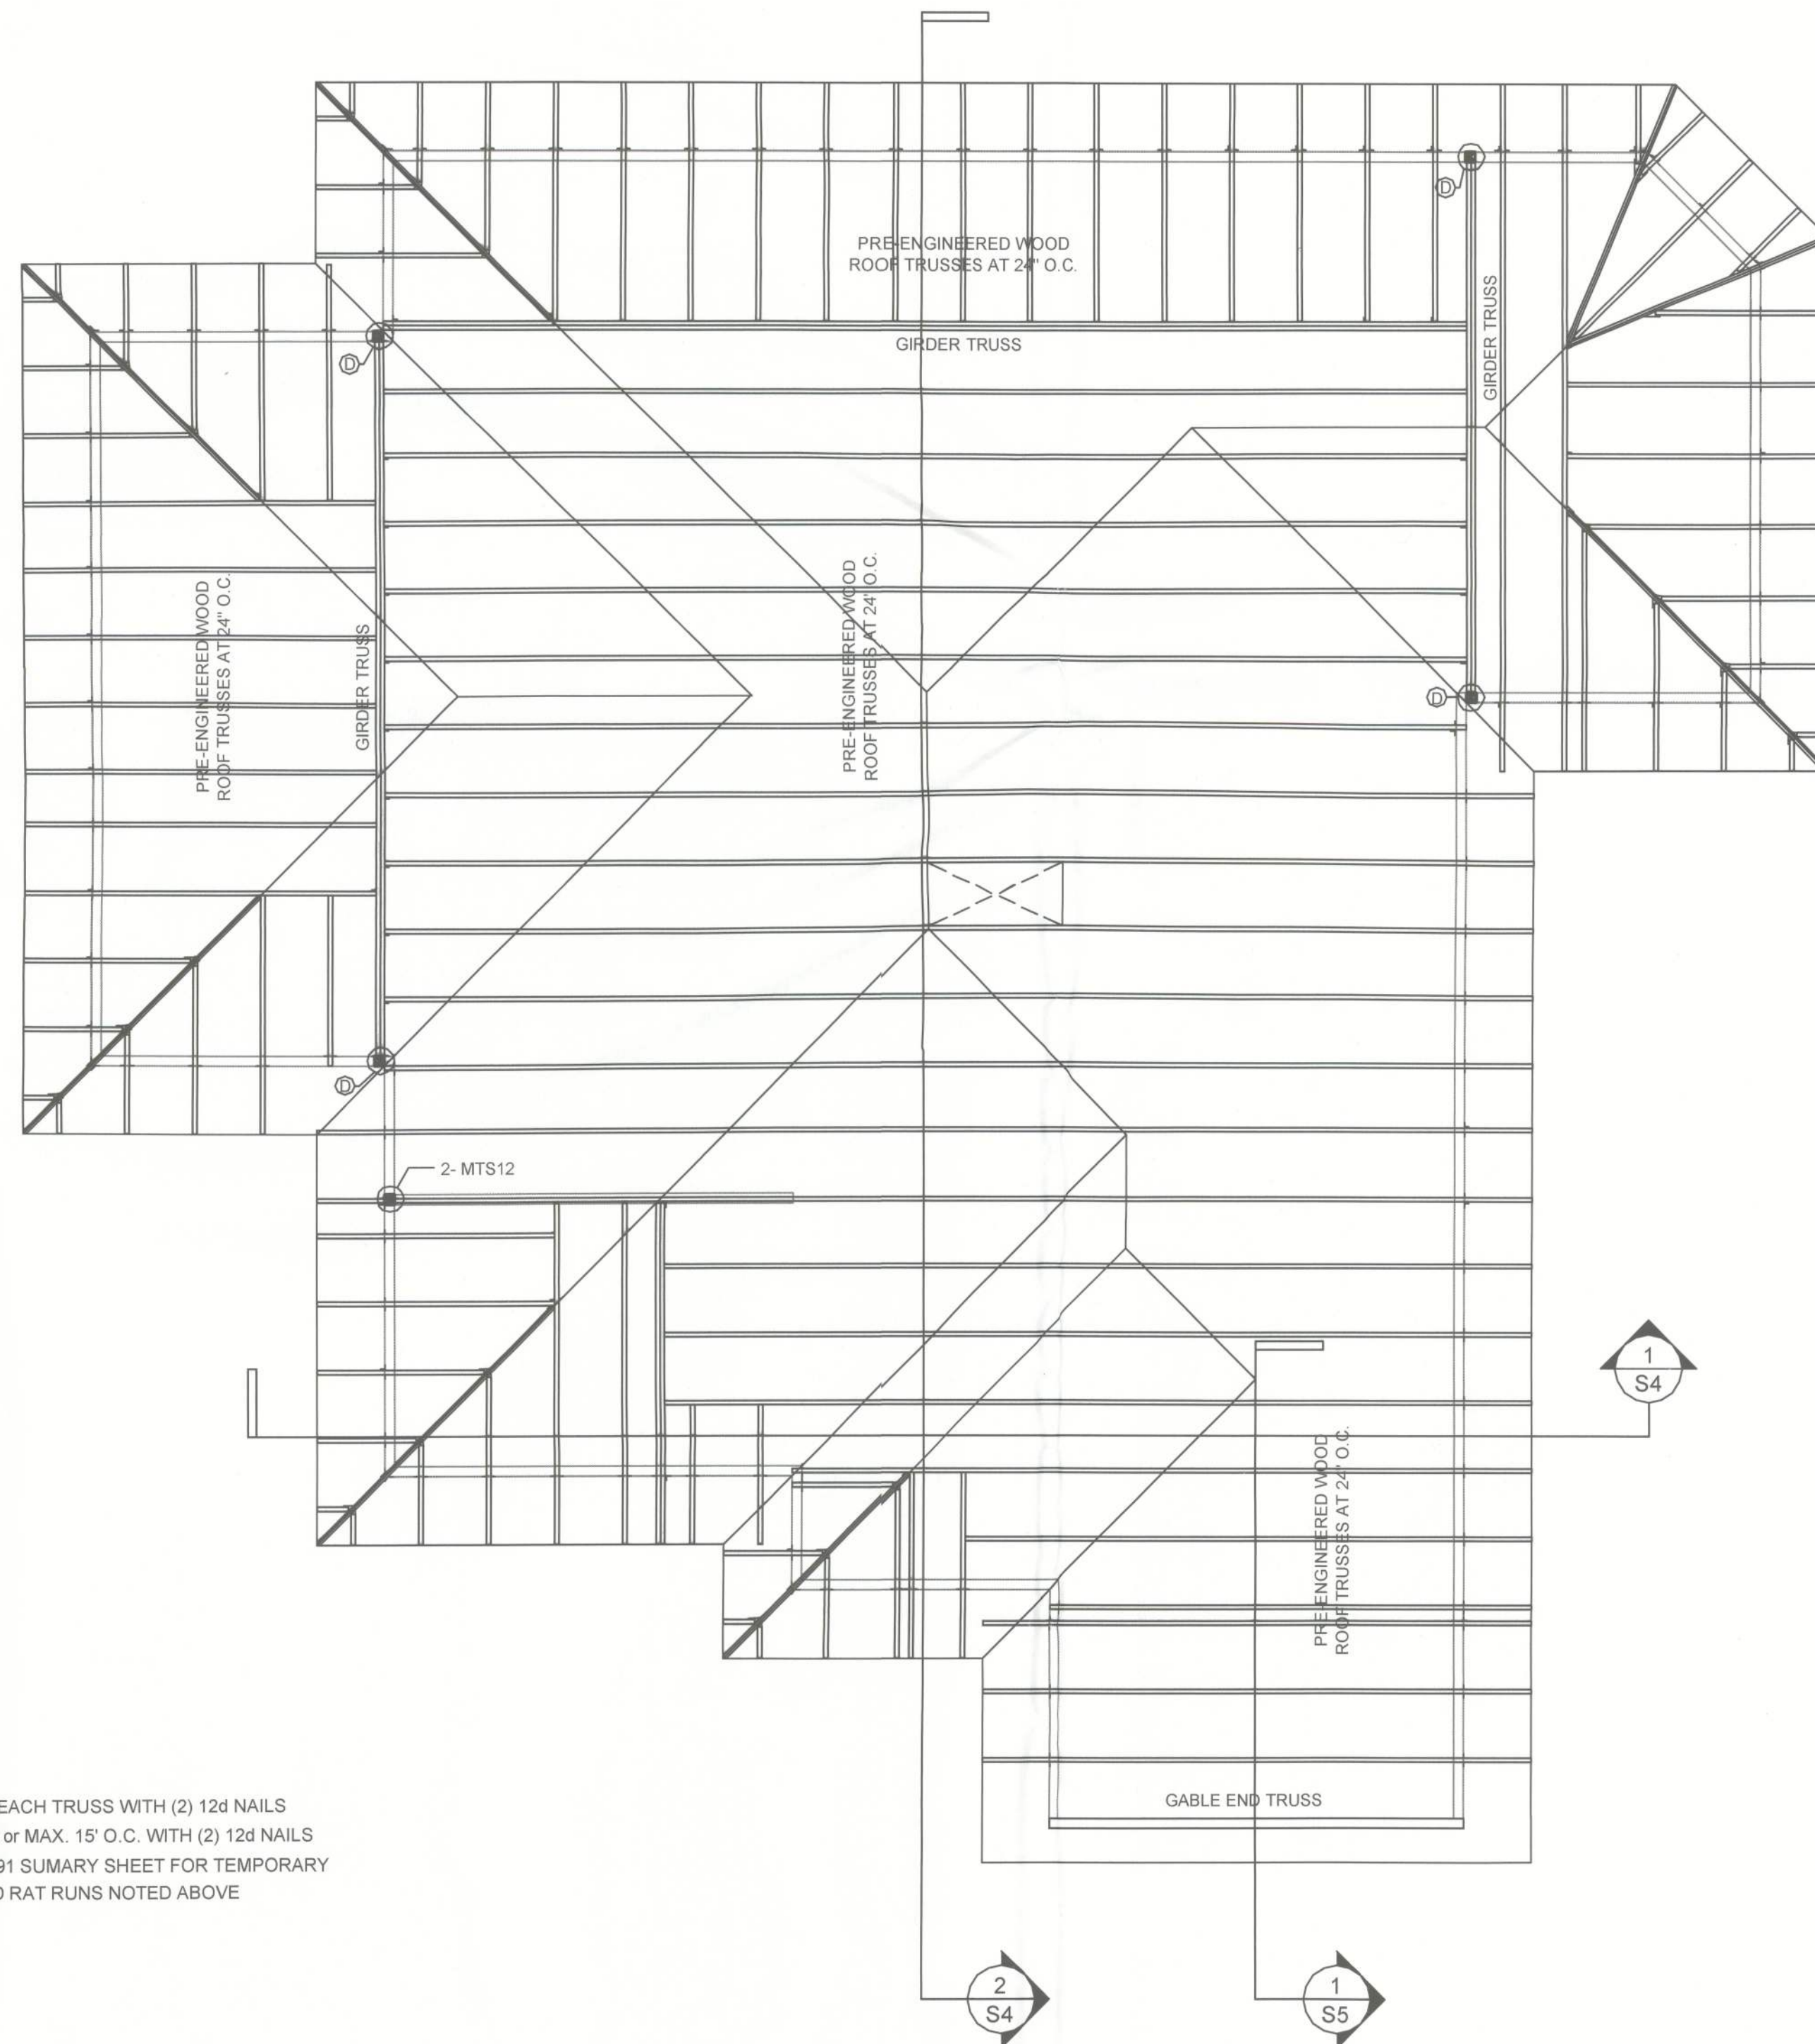

PERMANENT TRUSS BRACING

ATTACH BOTTOM CHORD BRACES ("RAT RUNS") AT MIN. 15'-0" O.C. NAILED TO EACH TRUSS WITH (2) 12d NAILS
X-BRACE TOP CHORD TO BOTTOM CHORD AT 20' INTERVALS ABOVE RAT RUNS or MAX. 15' O.C. WITH (2) 12d NAILS
SEE TRUSS ENGINEERING FOR PERMANENT WEB BRACES AND REFER TO HIB-91 SUMMARY SHEET FOR TEMPORARY
BRACING RECOMMENDATIONS USE 2x4 #2 SYP FOR ALL TRUSS X BRACING AND RAT RUNS NOTED ABOVE

UPPER ROOF FRAMING PLAN

SIMPSON H10 CLIP EACH END OF EACH TRUSS UNLESS NOTED OTHERWISE
ALL TRUSS-TO-TRUSS CONNECTORS FURNISHED BY TRUSS MANUFACTURER

SCALE: 1/4" = 1' 0"

SIMPSON STRONG-TIE CONNECTORS

TYPICAL ALL:
ROOF TRUSS AND RAFTERS H10 CLIP OR MTS12 STRAP
ROOF TRUSS AND RAFTERS HUS26 HANGER
ROOF GIRDERS HHUS28-2 HANGER
FLOOR TRUSSES HUS412 HANGER
FLOOR BEAMS HGUS412 HANGER
(UNLESS NOTED OTHERWISE ON PLANS)

- (A) = (2) MTS16 STRAP
IF ON POST USE 4x4 P.T. WITH DSP CLIP POST
AT BOTTOM
- (B) = (2) HTS20 STRAP
IF ON POST USE 4x4 LVL ENGINEERED POST
WITH HTT4 ANCHOR AT BOTTOM
- (C) = (2) MST27 STRAP BEAM TO 4x6 LVL
ENGINEERED POST WITH HTT5 ANCHOR AT
BOTTOM
- (D) = (1) MGT ANCHOR GIRDER WITH 5/8"
ALL-THREAD ROD TO INVERTED HTT4 ON 4x4
P.T. POST, THEN ADD (1) MST60 STRAP OVER
FLOORS TO LVL ENGINEERED POST ON FIRST
FLOOR WITH HTT5 ANCHOR BOTTOM

DATE	REMARKS
03.18.13	PERMIT SET

Ken Ehlers
3/18/13
Ken Ehlers P.E.# 18243

STRUCTURAL PLAN SERVICE, INC.
COA #27162 Box 840128
10000 W. 11th Ave., Suite 200
Miami, FL 33176
Phone (407) 295-8155
Fax (407) 295-8141
Ken Ehlers P.E.# 18243
LICENSED PROFESSIONAL ENGINEER


SPS

PLANS PREPARED BY AND UNDER THE
DIRECT SUPERVISION OF
STRUCTURAL PLAN SERVICE, INC.
AND KEN EHLERS, P.E.


PETER WOODS, RESIDENTIAL DESIGNER
1804 PICHAY RD., OCALA, FL 34472
pwoods@pwoodsdesign.com
(352) 575-4884

PROPOSED RESIDENCE
DENNILLE AND A.J. DECKER
468 NW HACKNEY TERRACE, LAKE CITY, FL 32055
PARCEL NO. 36-3S-16-02600-000


SHEET NUMBER
S3
PROJECT NO. 130103

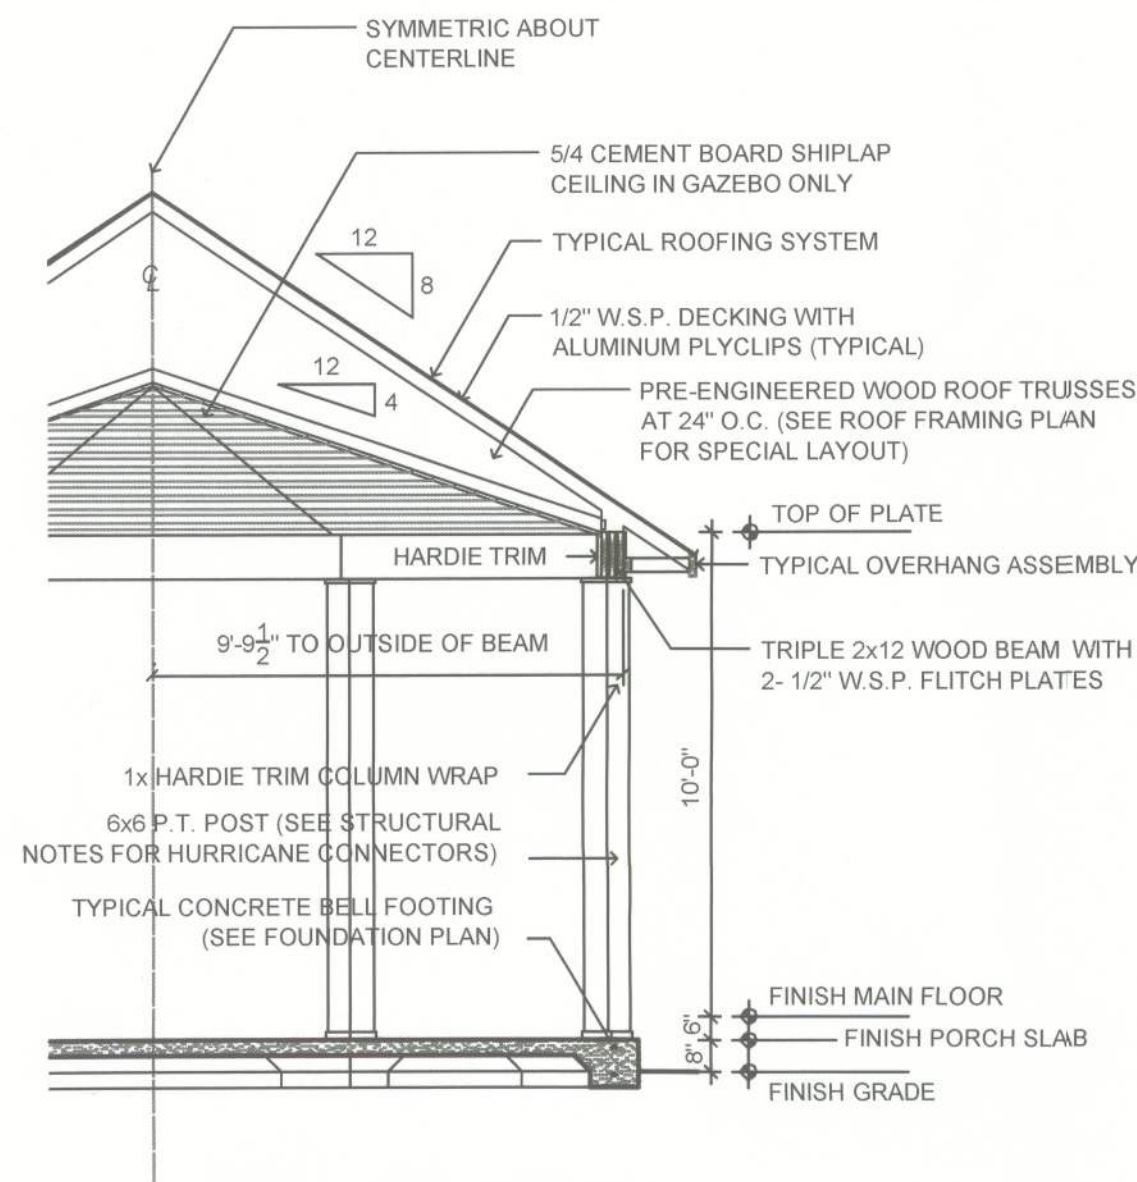

3
S4 SECTION
SCALE: 1/4" = 1' 0"

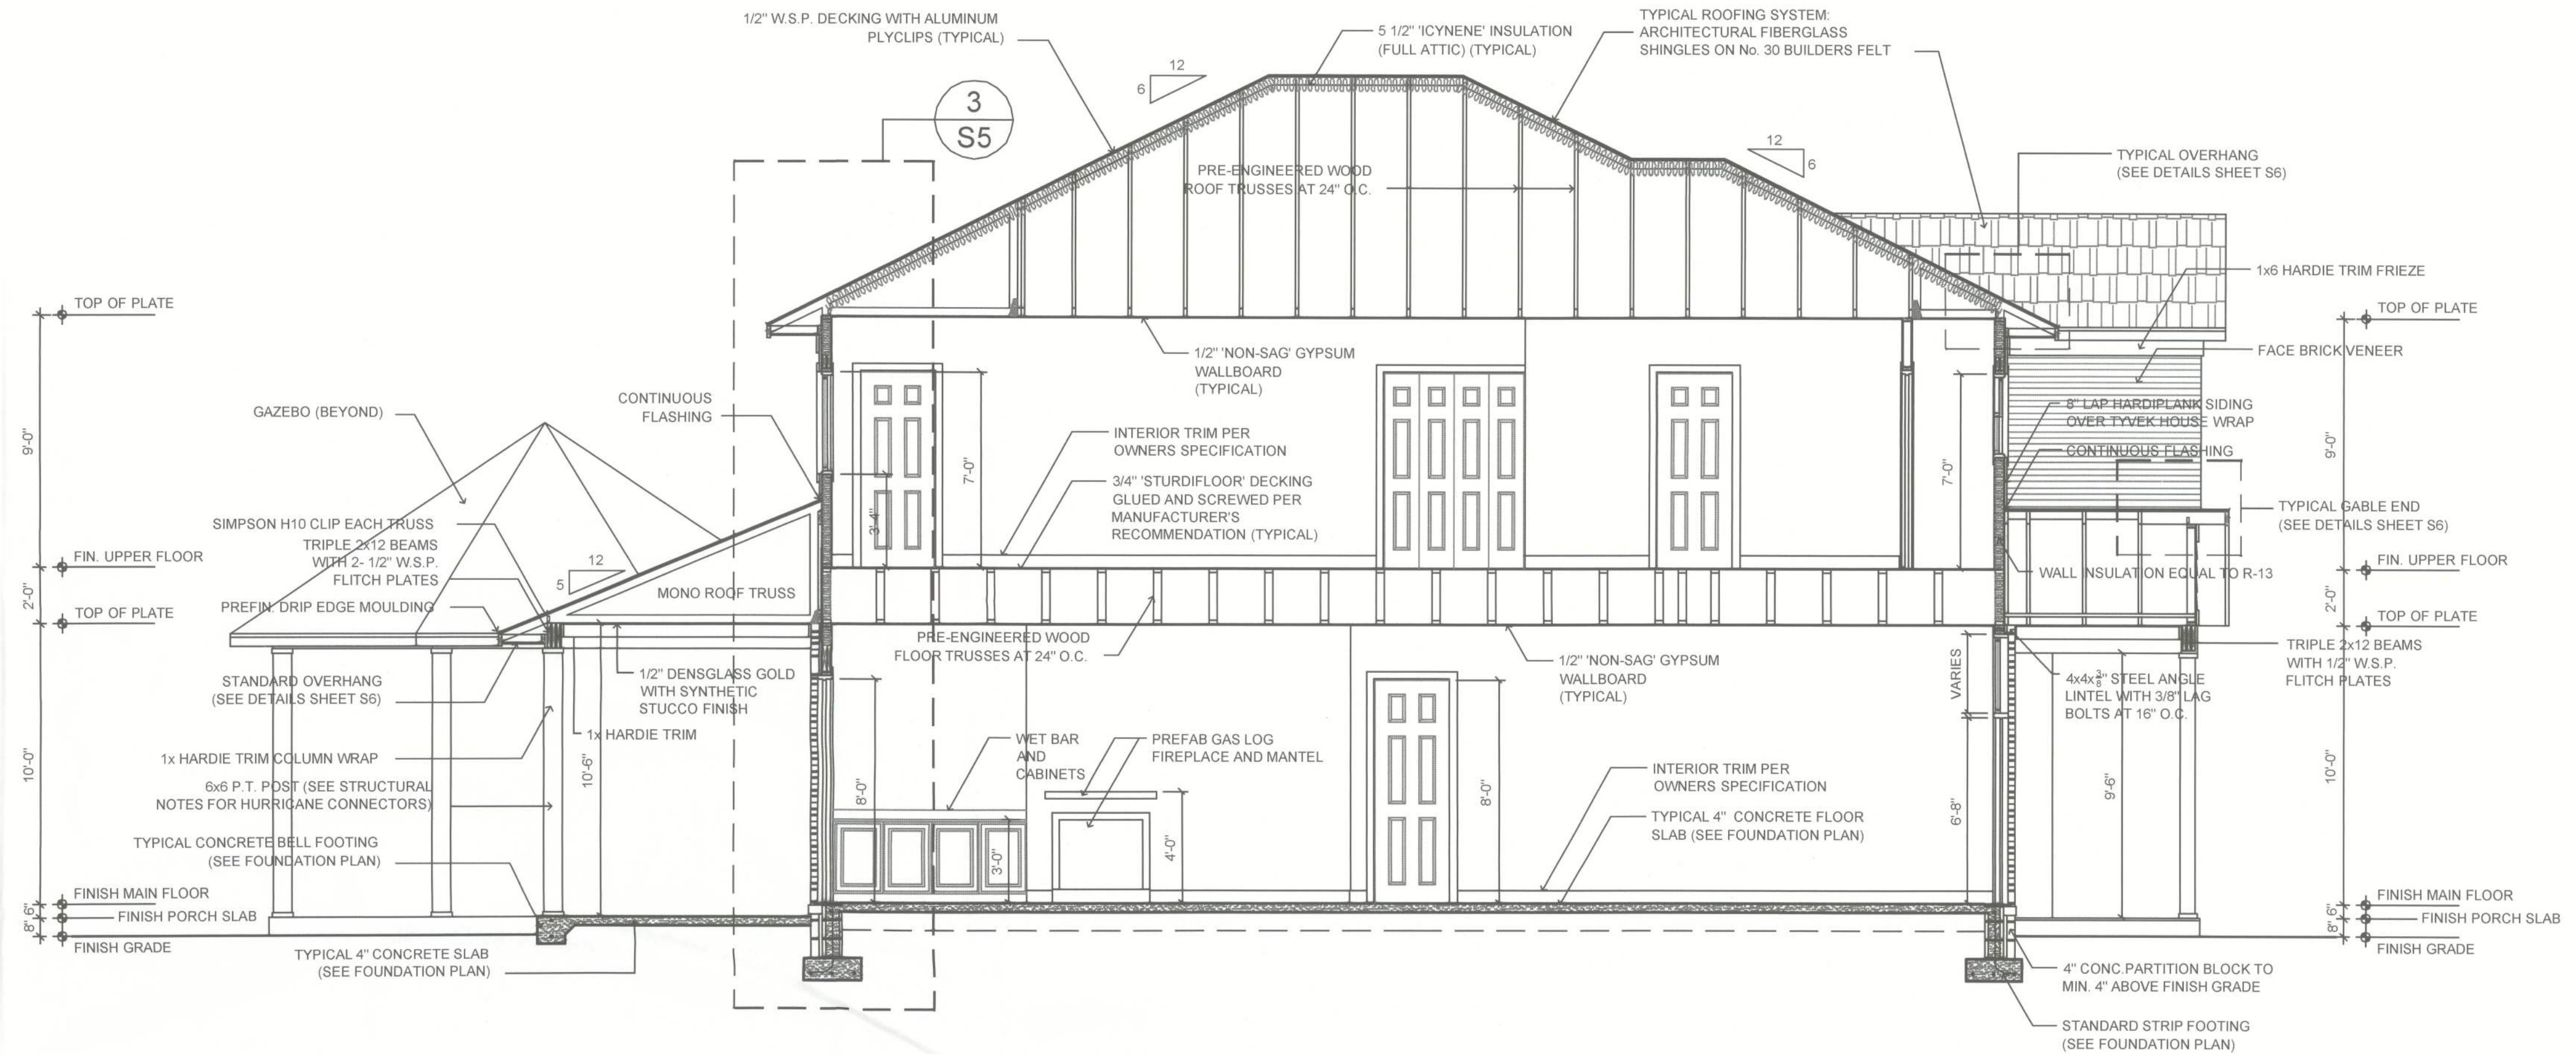

2
S4 FULL BUILDING SECTION
SCALE: 1/4" = 1' 0"

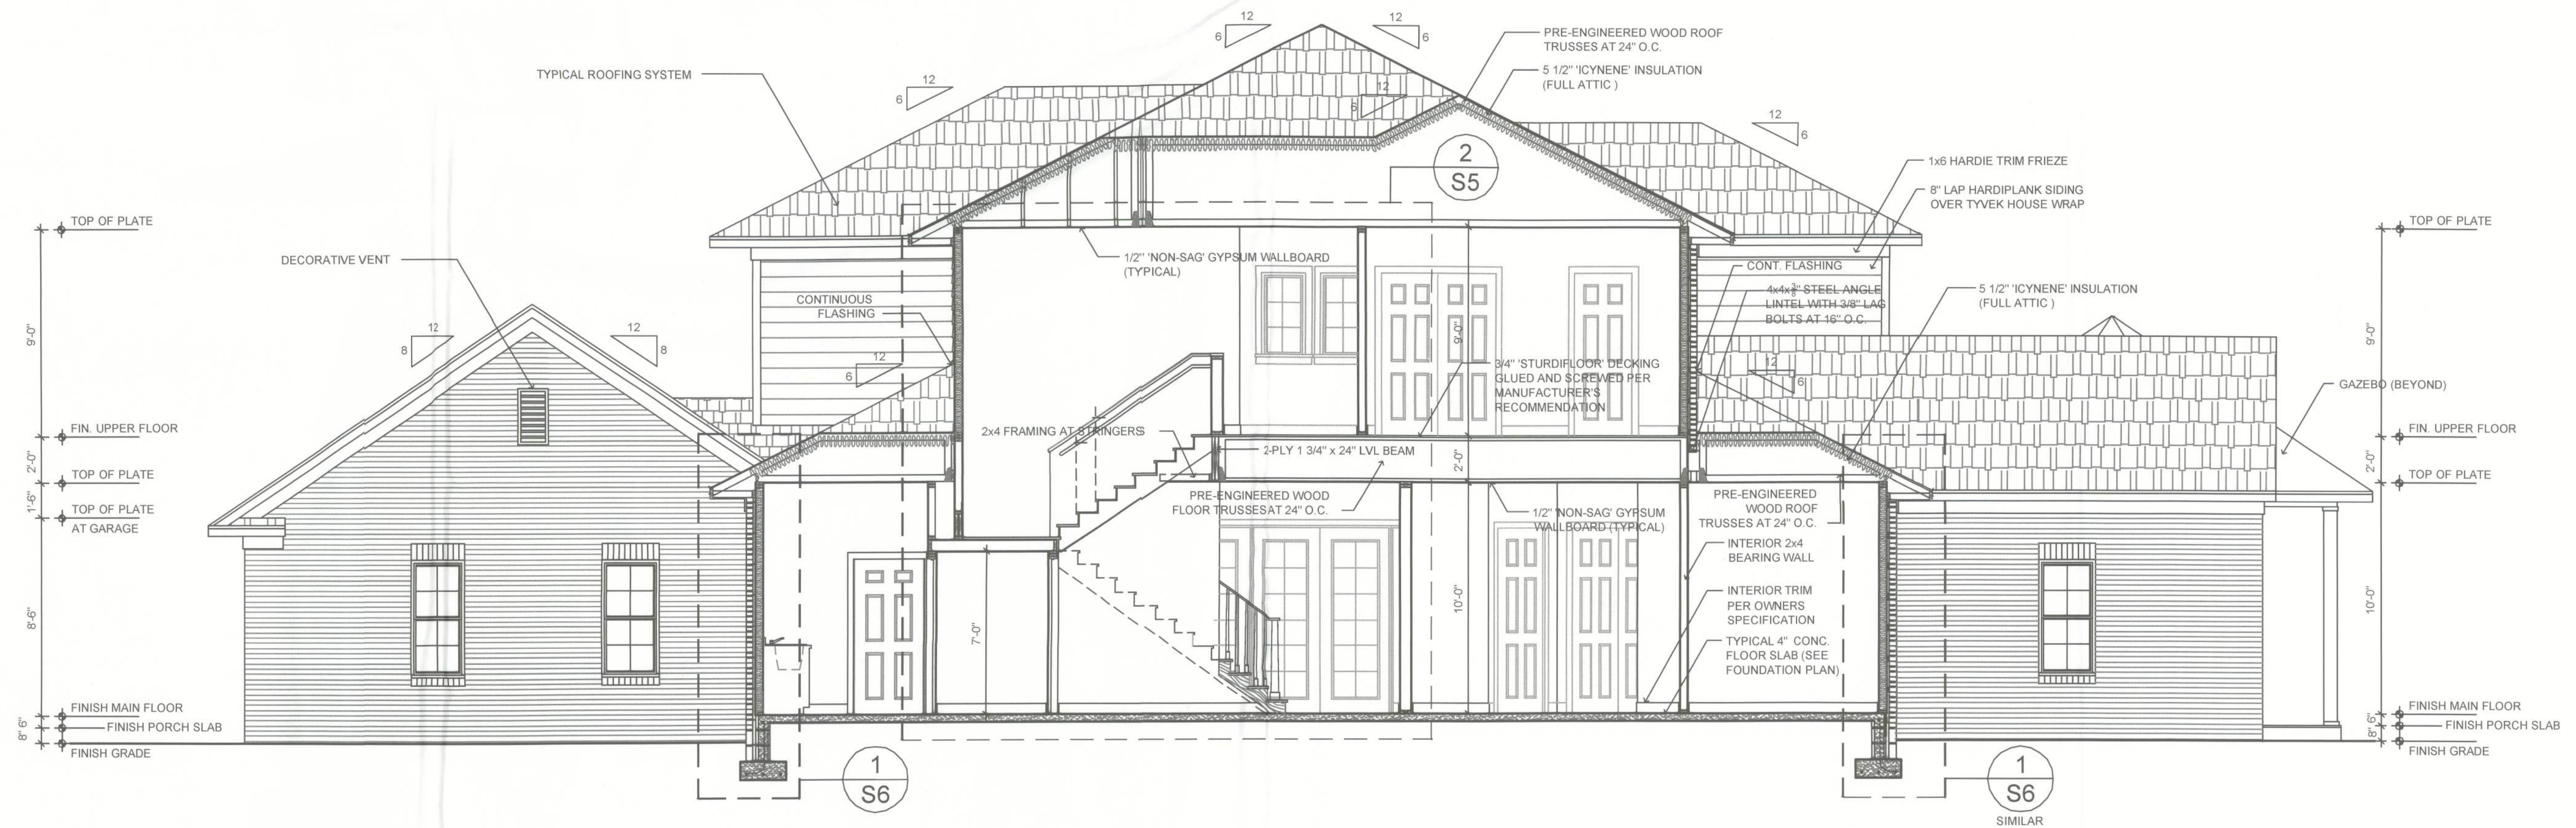

1
S6 FULL BUILDING SECTION
SCALE: 1/4" = 1' 0"

TYPICAL NOTES:
ANY NOTE DESCRIBING A TYPICAL CONDITION SHALL APPLY TO ALL SIMILAR CONDITIONS UNLESS NOTED OTHERWISE.

DATE	REMARKS
03.16.13	PERMIT SET

Ken Ehlers P.E. # 18243
3/18/13


STRUCTURAL PLAN SERVICE INC.
COA #27162
Post Office Box 940128
Maitland, FL 32794
Phone (407) 298-0165
Fax (407) 298-0165
Ken Ehlers P.E. # 18243
LICENSED PROFESSIONAL ENGINEER

PLANS PREPARED BY AND UNDER THE
DIRECT SUPERVISION OF
STRUCTURAL PLAN SERVICE INC.
AND KEN EHLERS, P.E.

PETER WOODS, RESIDENTIAL DESIGNER
SSM FIDM RFL COA, FL 9472
peter.woods@residentialplan.com
(352) 575-4884

PROPOSED RESIDENCE
DENNILLE AND A.J. DECKER
468 NW HACKNEY TERRACE, LAKE CITY, FL 32055
PARCEL NO. 36-3S-16-02600-000


SHEET NUMBER
S4
PROJECT NO. 130103

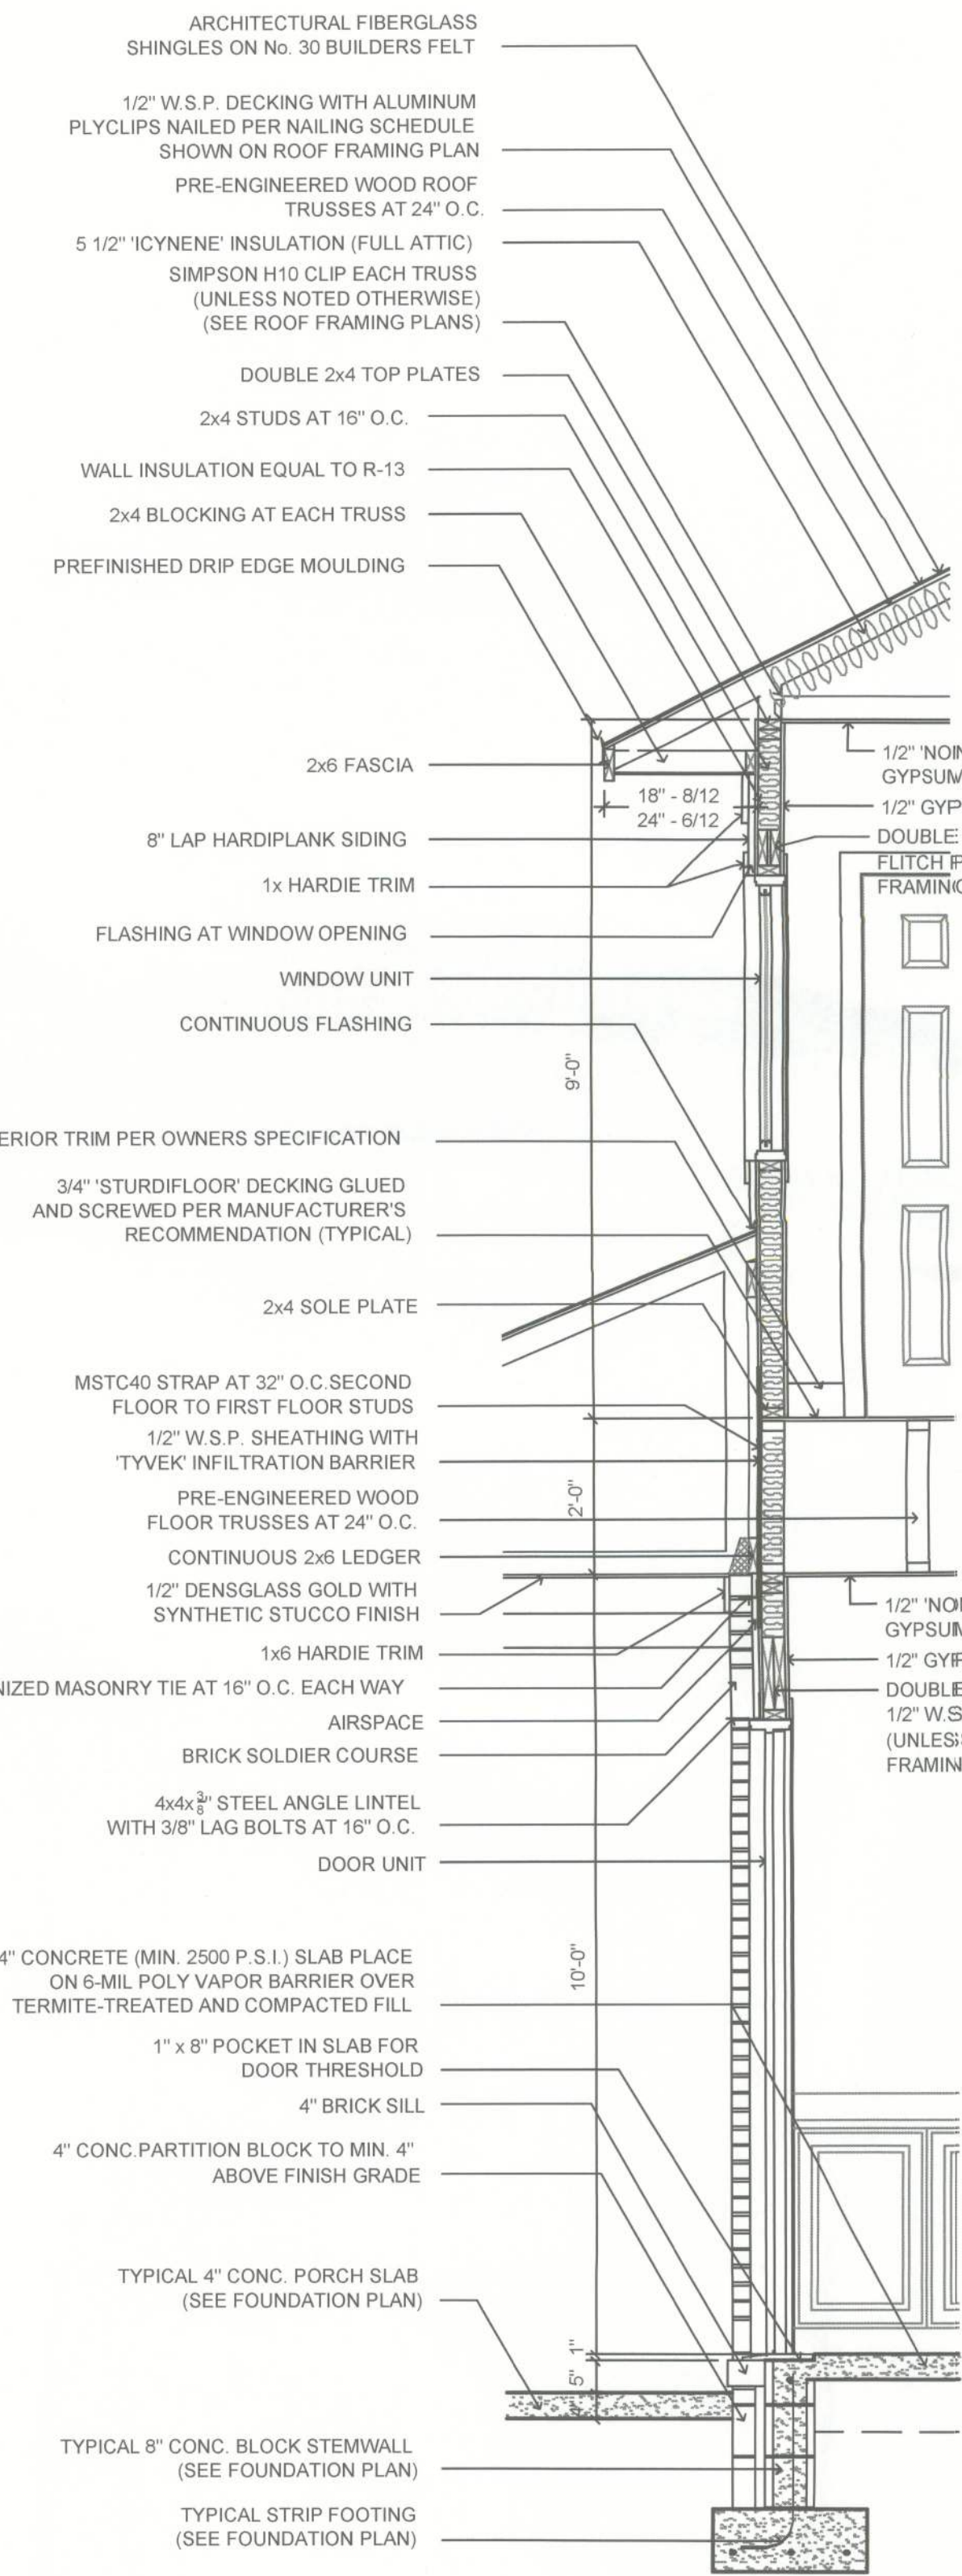

3
S5

TYPICAL WALL SECTION
(TWO STORY)

SCALE: 1/2" = 1' 0"

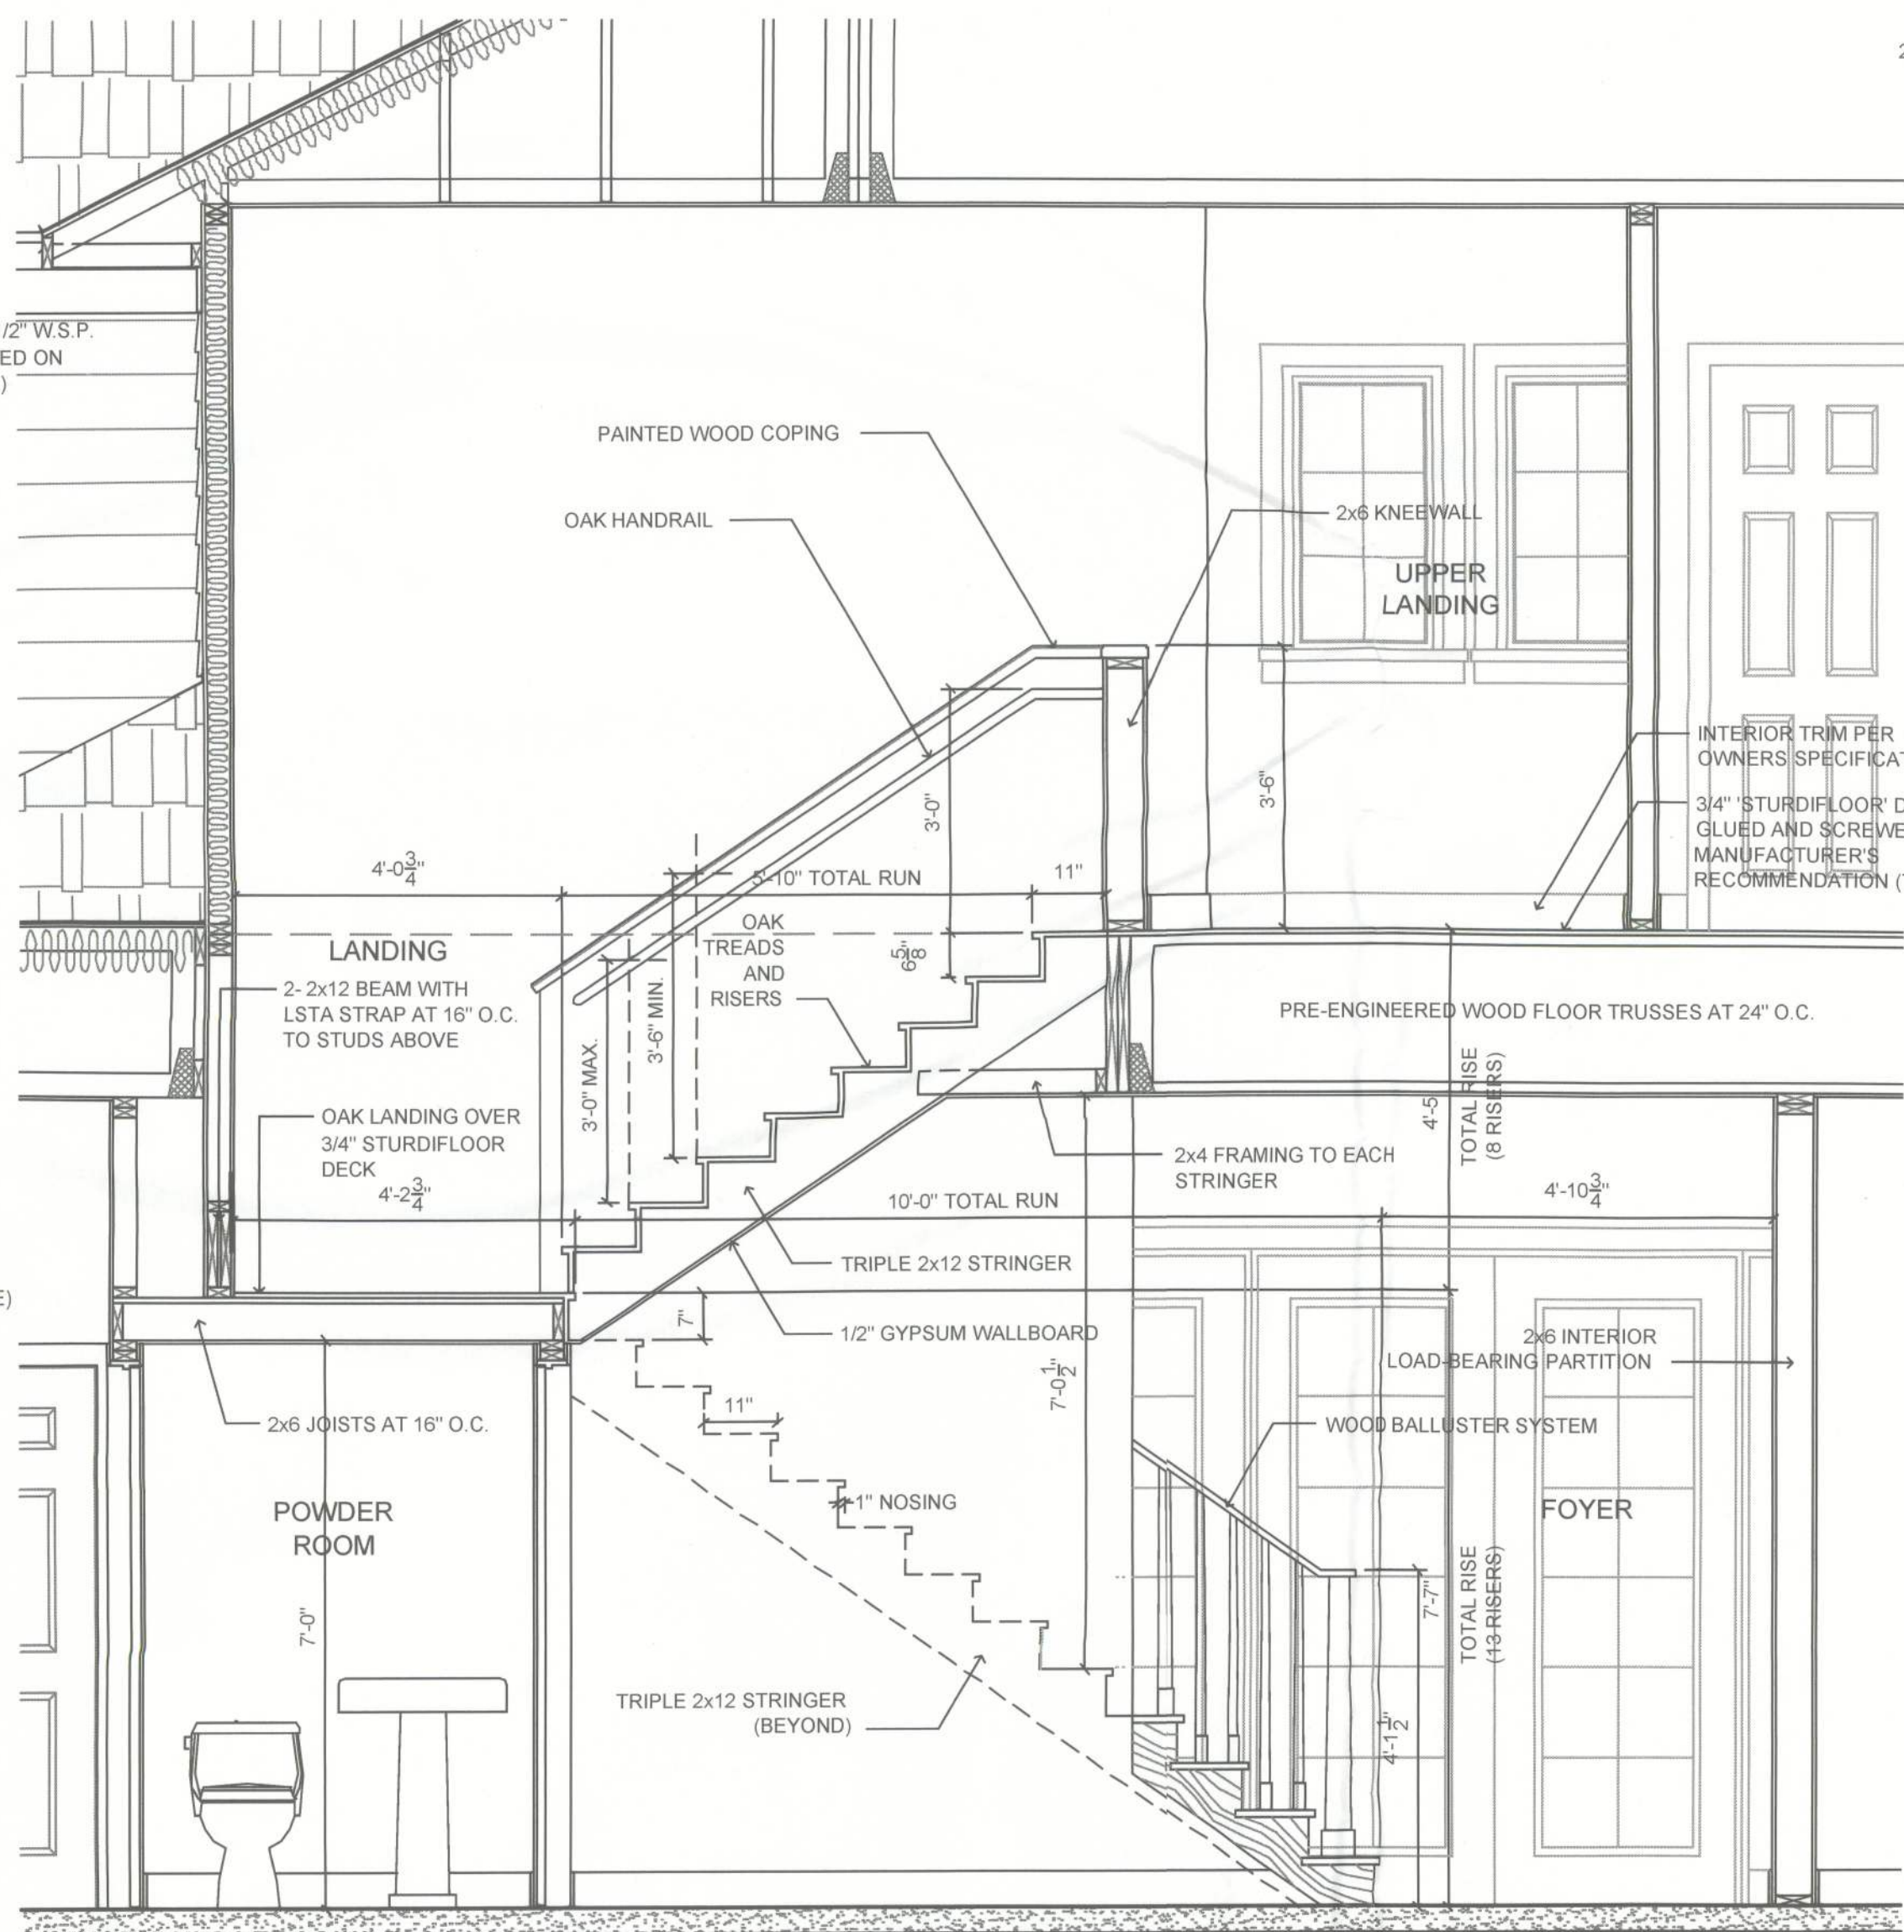


2
S5

STAIRS DETAILS

SCALE: 1/2" = 1' 0"


TYPICAL NOTES:
ANY NOTE DESCRIBING A TYPICAL CONDITION SHALL APPLY TO ALL SIMILAR CONDITIONS UNLESS NOTED OTHERWISE.

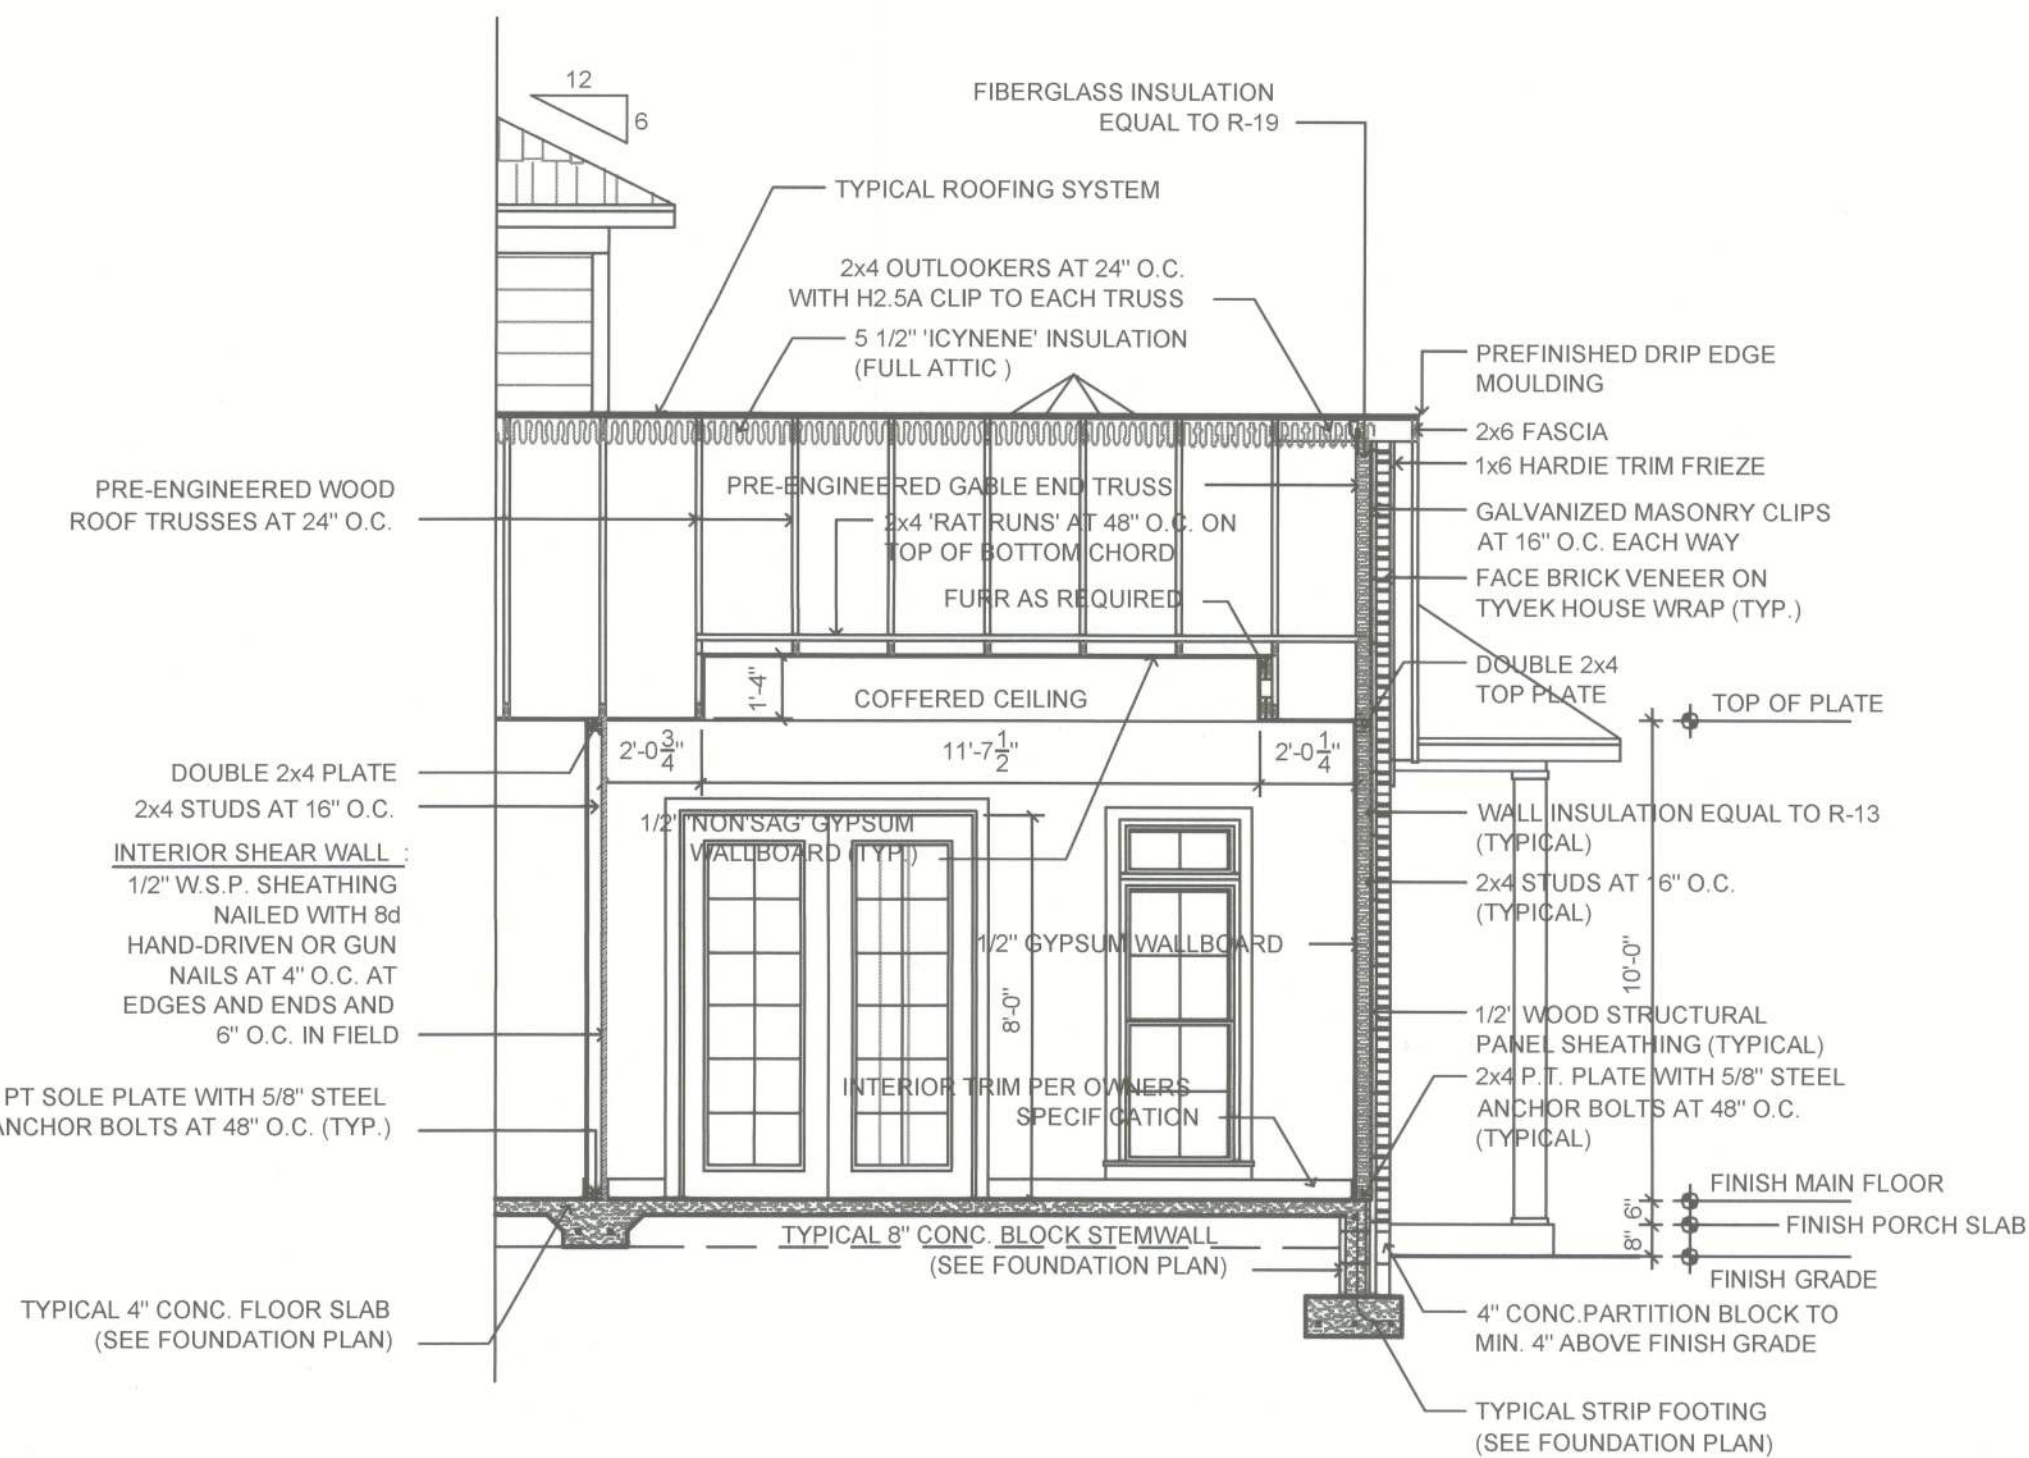

4
S5

SECTION

SCALE: 1/4" = 1' 0"

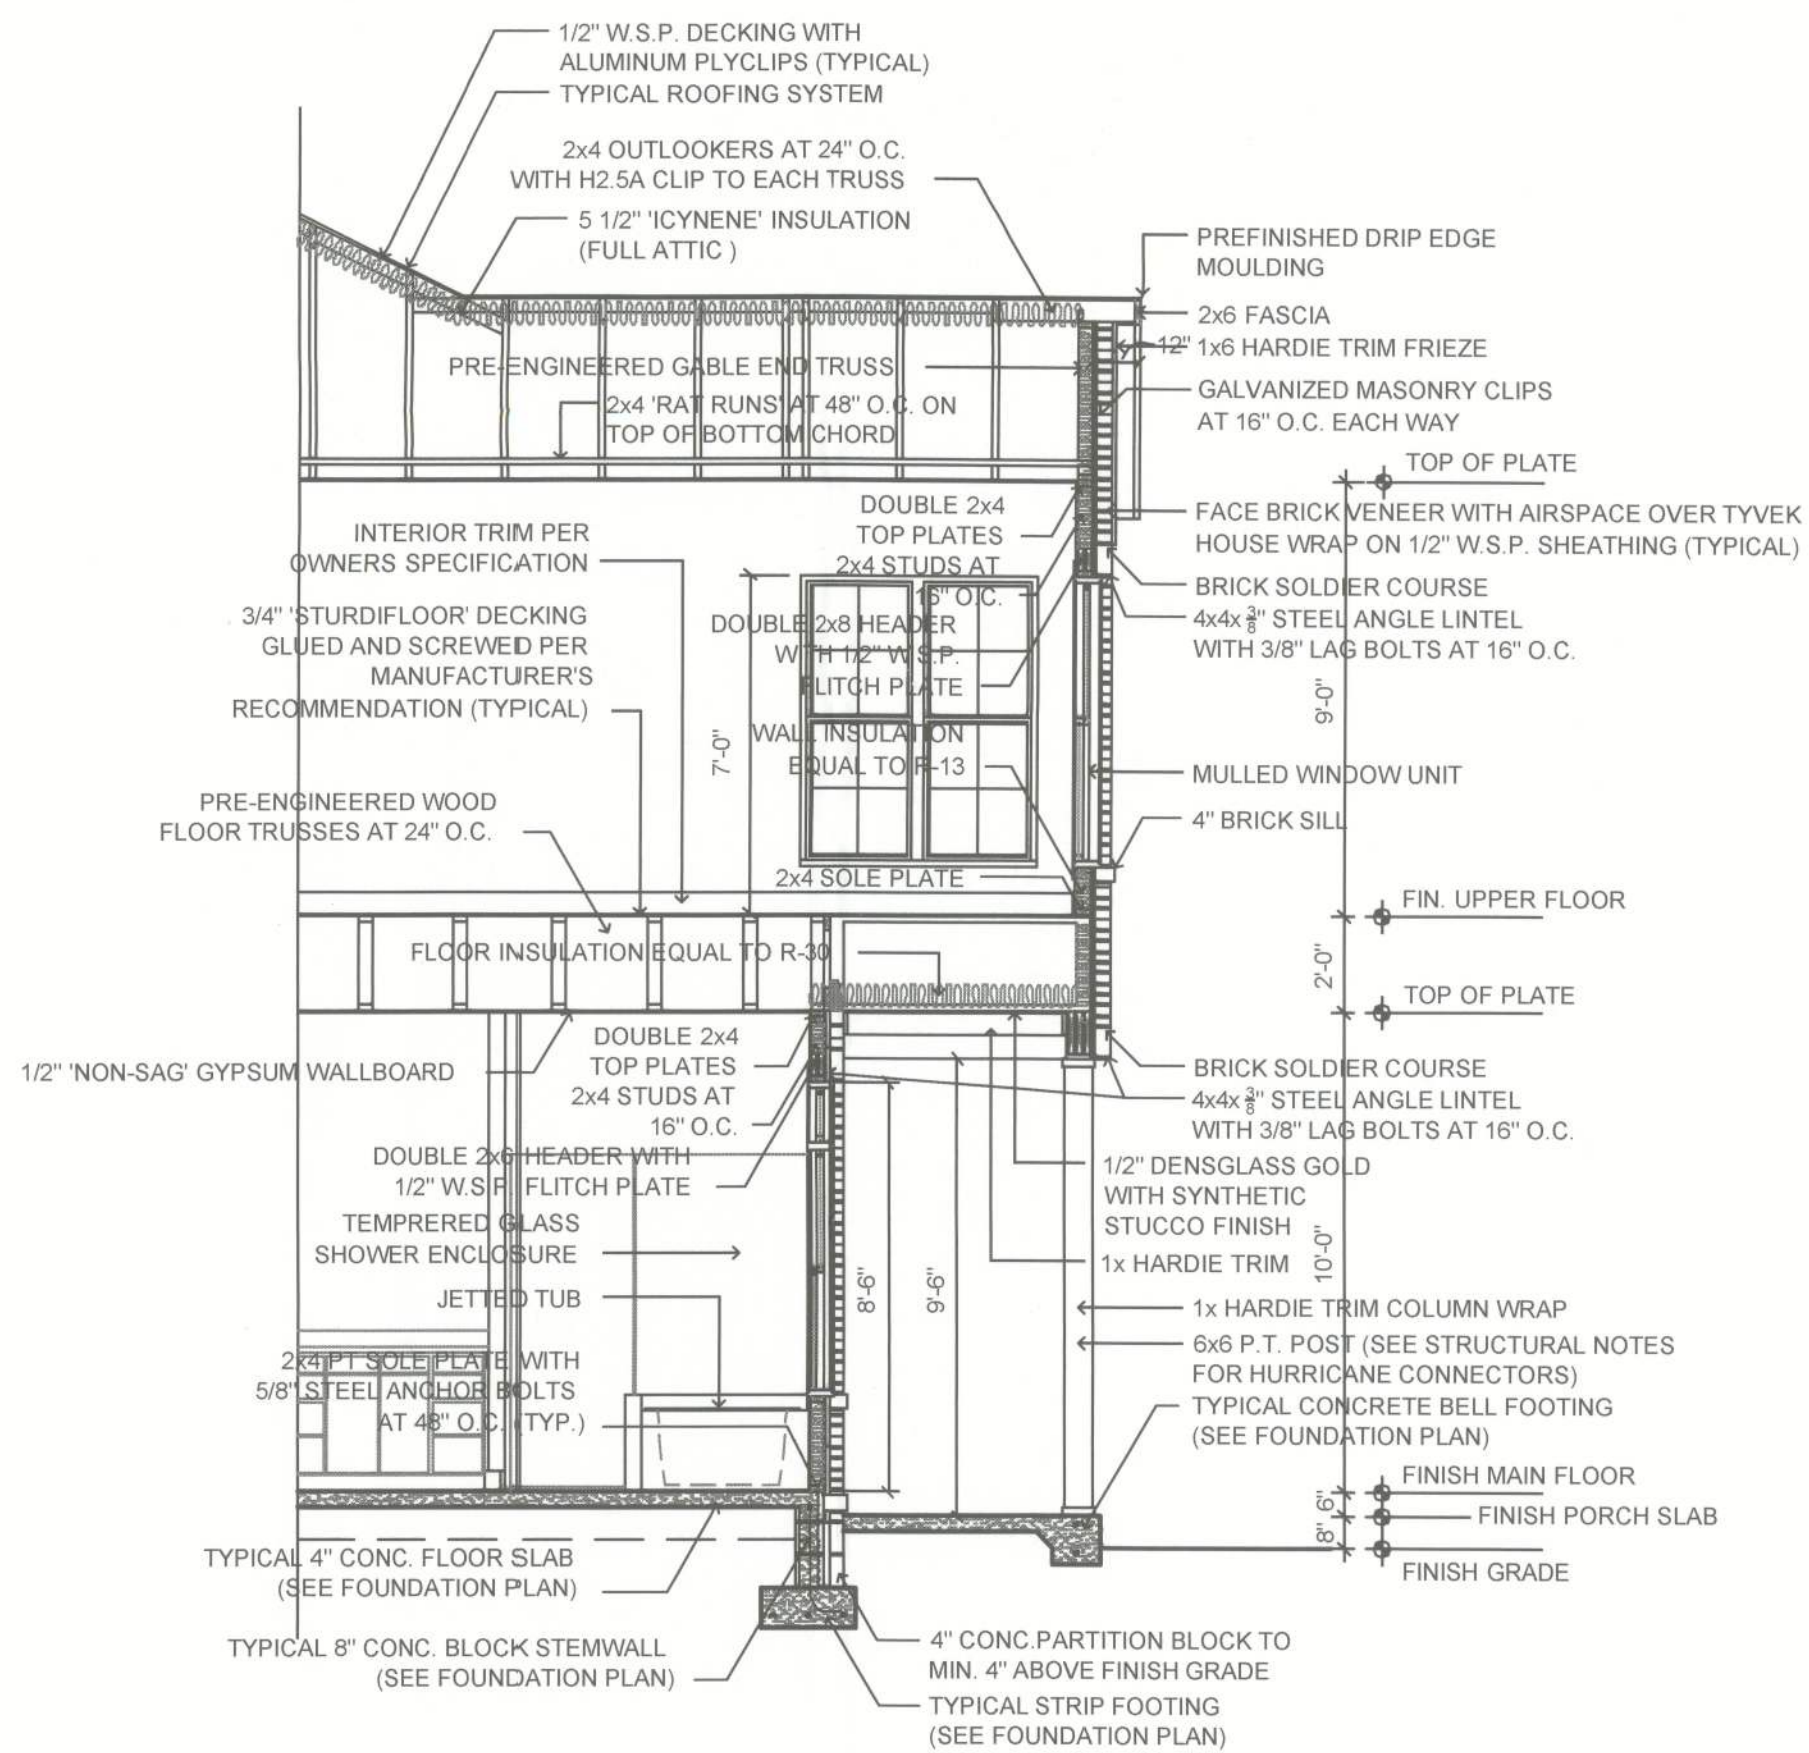

1
S5

SECTION

SCALE: 1/4" = 1' 0"

DATE	REMARKS
03.16.13	PERMIT SET

4 clear
3/15/13

Ken Ehlers P.E. # 18243

STRUCTURAL PLAN SERVICE, INC.
COA #27152
Post Office Box 940129
Metairie, LA 70004-0129
Phone (504) 885-1655
Fax (504) 885-0145
Ken Ehlers P.E. # 18243
LICENSED PROFESSIONAL ENGINEER

SPS

PLANS PREPARED BY AND UNDER THE
DIRECT SUPERVISION OF
STRUCTURAL PLAN SERVICE, INC.
AND KEN EHLERS, P.E.

PETER WOODS, RESIDENTIAL DESIGNER
3554 PEGAN HILL, COALA, FL 34472
peter.woods@denndecker.com
(352) 575-4884

PROPOSED RESIDENCE
DENNILLE AND A.J. DECKER
468 NW HACKNEY TERRACE, LAKE CITY, FL 32055
PARCEL NO. 36-3S-16-02600-000

SHEET NUMBER
S5
PROJECT NO. 130103

DATE	REMARKS
03.16.13	PERMIT SET

4 elev
3/15/13
Ken Ehlers P.E.# 18243

STRUCTURAL PLAN SERVICE INC.
COA #27152
Post Office Box 540128
Haitland, FL 34648
Phone (407) 286-8155
Fax (407) 286-8141
Ken Ehlers P.E.# 18243
LICENSED PROFESSIONAL ENGINEER


SPS

PLANS PREPARED BY AND UNDER THE
DIRECT SUPERVISION OF
STRUCTURAL PLAN SERVICE, INC.
AND KEN EHLERS, P.E.

PETER WOODS, RESIDENTIAL DESIGNER
564 PEDAN RD., COALA, FL 34472
peter.woods@residentialdesign.com
(352) 575-4884

PROPOSED RESIDENCE
DENNILLE AND A.J. DECKER
468 NW HACKNEY TERRACE, LAKE CITY, FL 32055
PARCEL NO. 36-3S-16-02600-000

SHEET NUMBER
S6
PROJECT NO. 130103

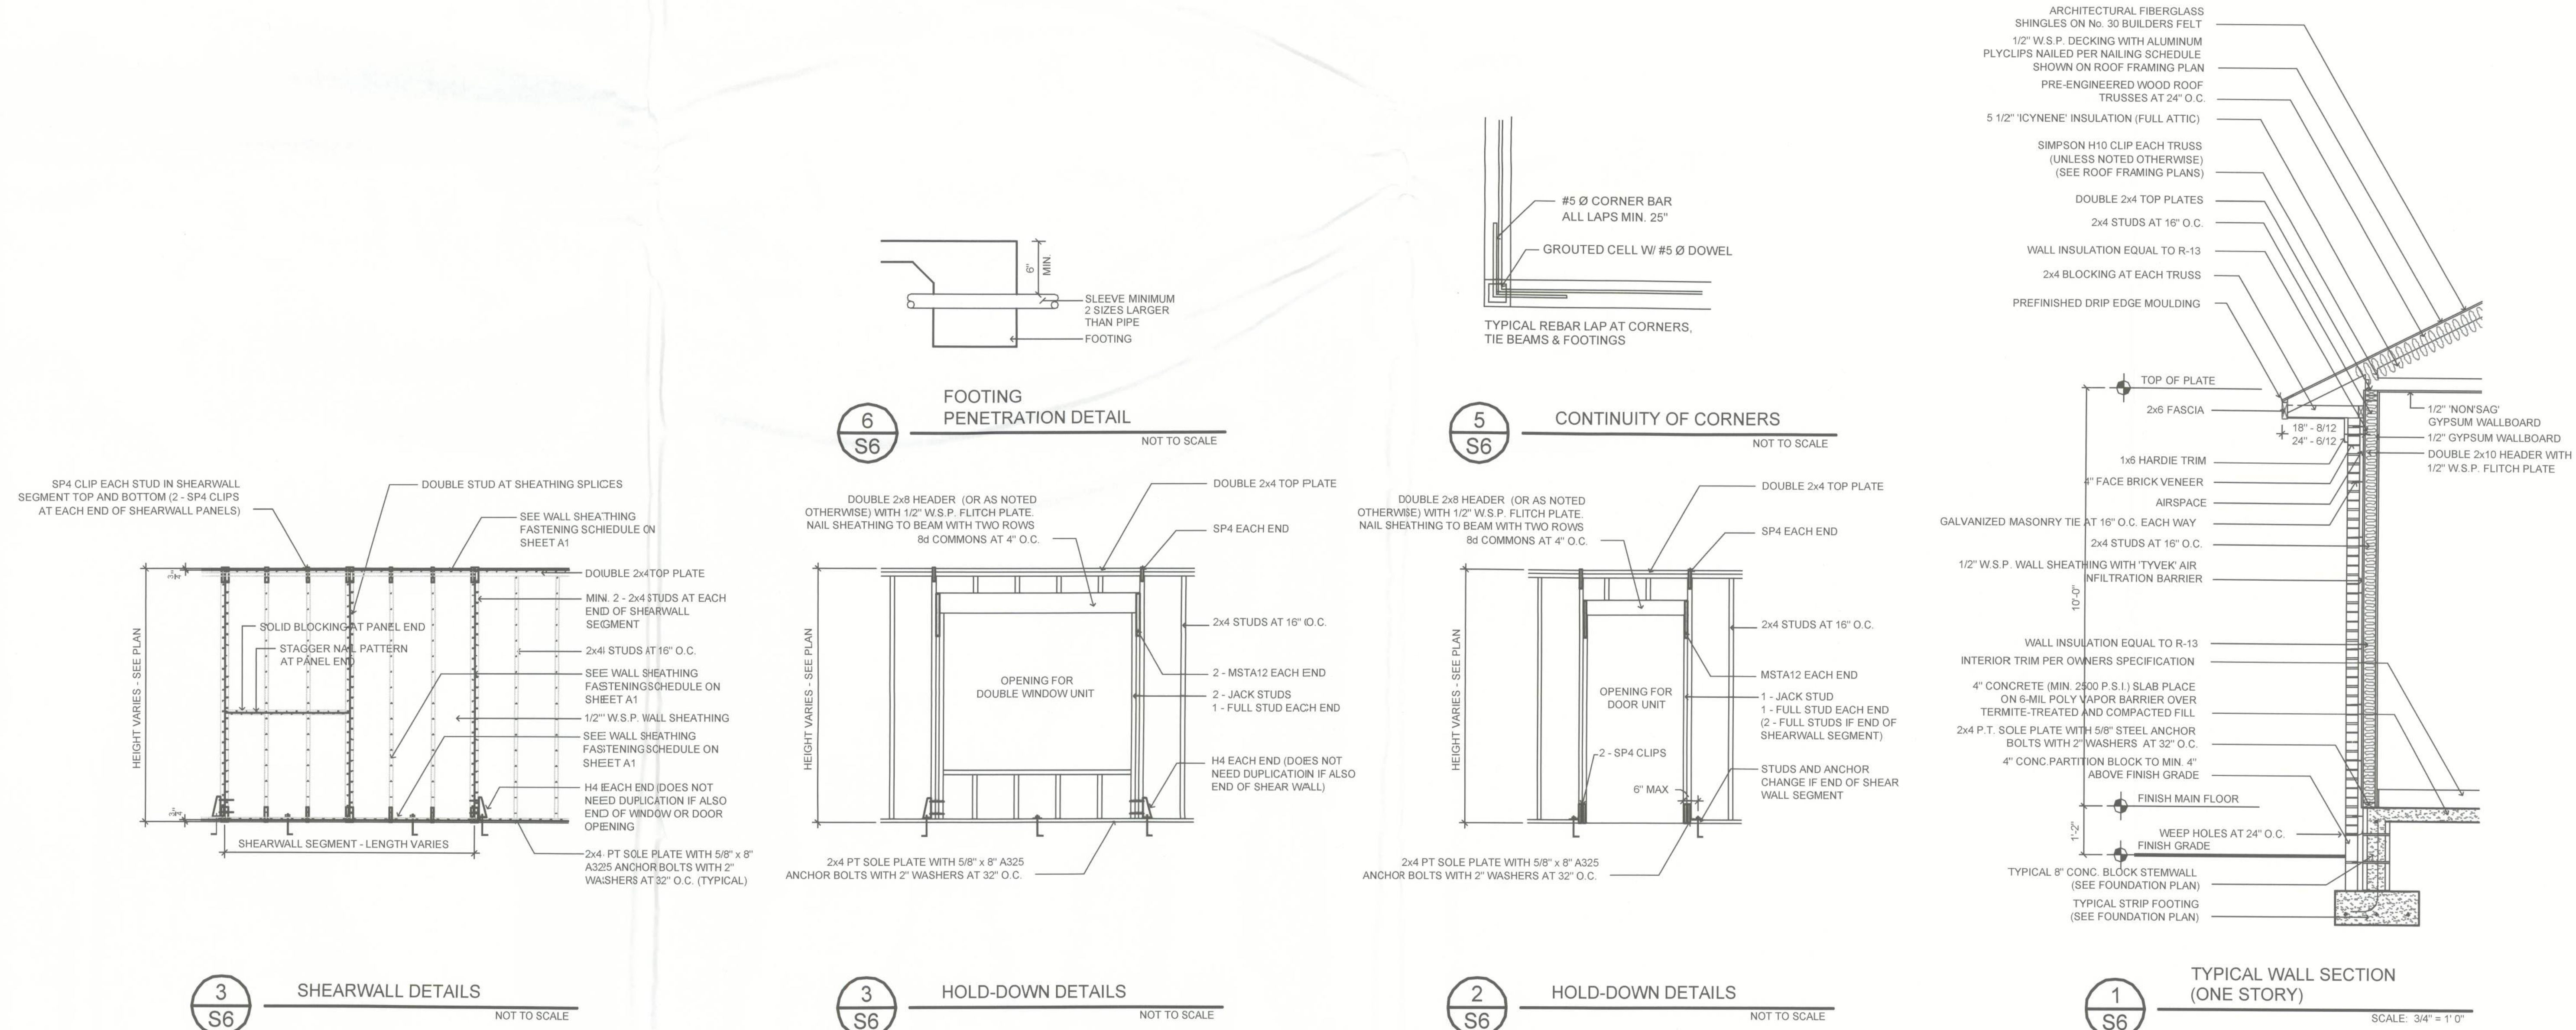

TYPICAL NOTES:
ANY NOTE DESCRIBING A TYPICAL CONDITION SHALL APPLY TO ALL SIMILAR CONDITIONS UNLESS NOTED OTHERWISE.