
REVISIONS

05/17/04 TMR

05/19/04 TMR

08/31/04 TMR



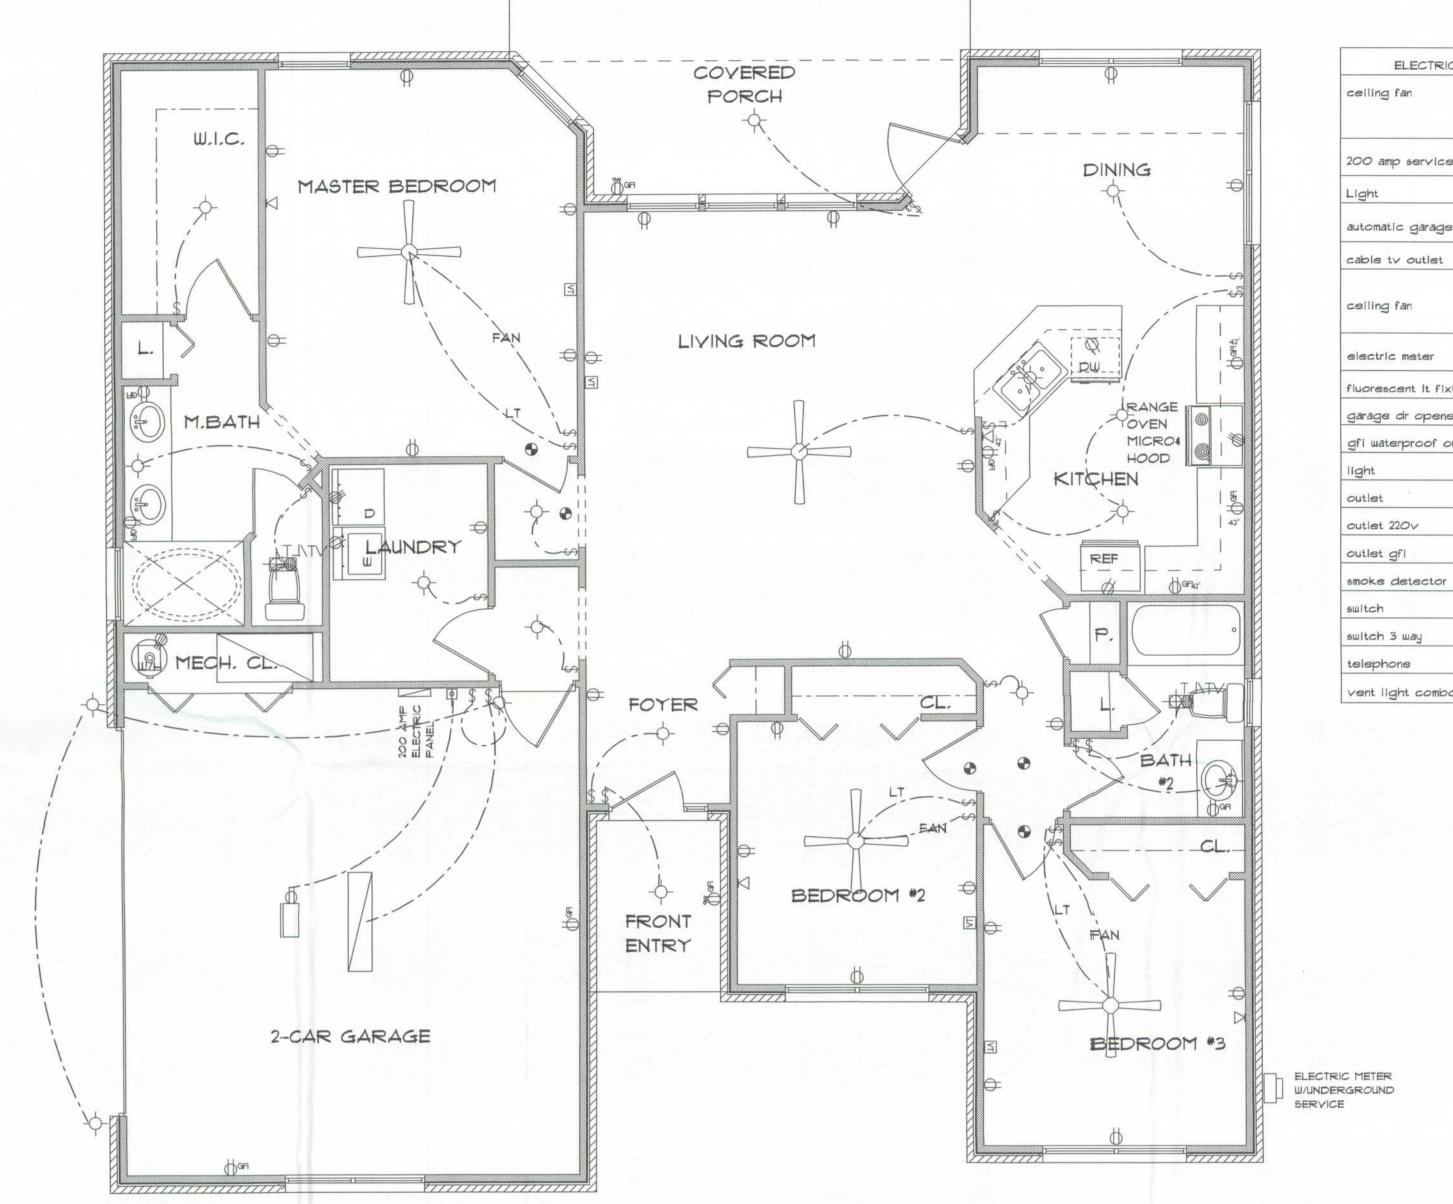

ELECTRICAL	COUNT	SYMB
ceiling fan	2	
200 amp service panel	1	200 AHF
Light	6	
automatic garage dr opener	1	
cable tv outlet	4	M
celling fan	2	-
electric meter	1	BLECTRIC H WANDERGR SERVICE
fluorescent It fixture	1	
garage dr opener	1	ф
gfi waterproof outlet	2	Q ₂₀
light	11	-
outlet	28	ő
outlet 220v	3	ă
outlet gfi	9	Q-m
smoke detector	5	•
switch	22	\$
ewitch 3 way	3	\$.
telephone	4	▽
vent light combo	2	VIAT

ELECTRICIAL PLAN NOTES

- E-1 WIRE ALL APPLIANCES, HYAC UNITS AND OTHER EQUIPMENT PER MANUFACTORS SPECIFICATIONS.
- E-2 CONSULT THE OWNER FOR THE NUMBER OF SEPERATE TELEPHONE LINES TO BE INSTALLED.
- E-3 ALL INSTALLATIONS SHALL BE PER NATIONAL ELECTRIC CODE.
- E-4 ALL SMOKE DETECTORS SHALL BE 120V W/BATTERY BACKUP OF THE PHOTOELECTRIC TYPE, AND SHALL BE INTERLOCKED TOGETHER. INSTALL INSIDE AND NEAR ALL BEDROOMS.
- E-5
 TELEPHONE, TELEVVISION AND OTHER LOW VOLTAGE DEVICES
 OR OUTLETS SHALL BE AS PER THE OWNERS DIRECTION AND IN
 ACCORDANCE WITH APPLICABLE SECTIONS OF NATIONAL ELCT.
 CODE LATEST EDITION.
- E-6 ELECTRICAL CONTRACTOR SHALL BE RESPONSIBLE FOR THE DESIGN AND SIZING OF ELECTRICAL SERVICE AND CIRCUITS.
- E-7 ENTRY OF SERVICE UNDERGROUND OR OVERHEAD) IS TO BE DETERMINED BY THE POWER COMPANY.
- E-8 ALL BEDROOM RECEPTICALS ARE TO BE AFCI (ARC FAULT CIRCUIT INTERRUPT)

* ELECTRICAL PLAN *

SCALE : 1/4" = 1'-0"

"THE SAMUEL"

LOT *96

EMERALD COVE

LAKE CITY FLORIDA

Teena M. Ruffo
251 NW Hall of Fame Dr.
Lake City, Florida 32055
Phone: (386) 755 - 9993
Cell: (386) 867 - 1191
Email: easystreet®lani.net

PRINTED DATE:
November 04, 2005

DRAWN BY: CHECKED BY:

Teena M. Ruffo

DESIGNED BY:
Teena M. Rufo

FINIALS DATE:

JOB NUMBER:

A-2

OF 2 SHEETS