

## EQUIPOTENTIAL BONDING GRID:

ALL METAL PARTS SPECIFIED IN 680.26(B) MUST BE BONDED TO AN EQUIPOTENTIAL BONDING GRID WITH A SOLID COPPER CONDUCTOR NOT SMALL THAN 8 AWG. THE TERMINATION OF THE BONDING CONDUCTOR MUST BE MADE BY EXOTHERMIC WELDING, LISTED PRESSURE CONNECTORS, OR LISTED CLAMPS THAT ARE LABELED AS SUITABLE FOR THE PURPOSE. THE QUIPOTENTIAL BONDING GRID MUST EXTEND UNDER PAVED WALKING SURFACES FOR 3 FEET HORIZONTALLY FROM THE WATER (680.26(C)).

THE EQUIPOTENTIAL BONDING GRID MUST BE FORMED FROM EITHER OR BOTH OF:

THE STRUCTURAL REINFORCING STEEL OF A CONCRETE PERMANENTLY INSTALLED POOL, OUTDOOR SPA, OR OUTDOOR HOT TUB, TIED TOGETHER BY THE USUAL STEEL TIE WIRES.

THE METAL WALLS OF A PERMANENTLY INSTALLED POOL, OUTDOOR SPA, OR OUTDOOR HOT TUB

THE EQUIPOTENTIAL BONDING GRID CAN BE CONSTRUCTED WITH 8 AWG BARE SOLID COPPER CONDUCTORS BONDED TO EA OTHER AT ALL POINTS OF CROSSING BY EXOTHERMIC WELDING, LISTED PRESSURE CONNECTORS OF THE SET SCREW OR COMPRESSION TYPE, LISTED CLAMPS, OR OTHER LISTED FITTINGS (250.8).

THE EQUIPOTENTIAL BONDING GRID MUST COVER THE CONTOUR OF THE PERMANENTLY INSTALLED POOL, OUTDOOR SPA OR HOT TUB AND DECK EXTENDING 3 FEET HORIZONTALLY FROM THE WATER. THE EQUIPOTENTIAL BONDING GRID MUST BE ARRANGED IN A 1-FOOT BY 1-FOOT NETWORK OF 8 AWG CONDUCTORS, WITH A TOLERANCE OF 4 INCHES.


EXCEPTION: THE EQUIPOTENTIAL BONDING GRID SHALL NOT BE REQ'D TO BE INSTALLED UNDER THE BOTTOM OR VERTICALLY ALONG THE WALLS OF VINYL LINED POLYMER WALL, FIBERGLASS COMPOSITE, OR OTHER POOLS CONSTRUCTED OF NON-CONDUCTIVE MATERIALS.

ANY METAL PARTS OF THE POOL, INCLUDING METAL STRUCTURAL SUPPORTS, SHALL BE BONDED IN ACCORDANCE WITH 680.26(B). Poured concrete, pneumatically-applied concrete, and concrete block shall be considered conductive material

### GENERAL NOTES:

- 1) Per UL listing, pool motors require GFCI protection
- 2) FSPA requires the motor controller to be capable of 2 speeds, a time clock will not satisfy this unless it has 2 trip settings.
- 3) If heater installed (other than solar), it must comply with FBC-EC403.9.1 & have a cover per 403.9.3 (this applies to mechanical (not solar) heaters---cover required)
- 4) Outdoor swimming pools shall be provided with a barrier complying with Sections R4501.17.1.1 through R4501.17.1.14.
- 5) NEC 680.26(C) requires a conductive metal part of 9 sq. in. in direct contact with the pool water.
- 6) R4501.17.1.9 All doors and windows providing direct access from the home to the pool shall be equipped with an exit alarm complying with UL 2017 that has a minimum sound pressure rating of 85 dB at 10 feet.


STEPS: MIN. TREAD 10" x 12", 7" MIN RISER, 12" MAX RISER. INTERMEDIATE TREADS AND RISERS TO BE UNIFORM.

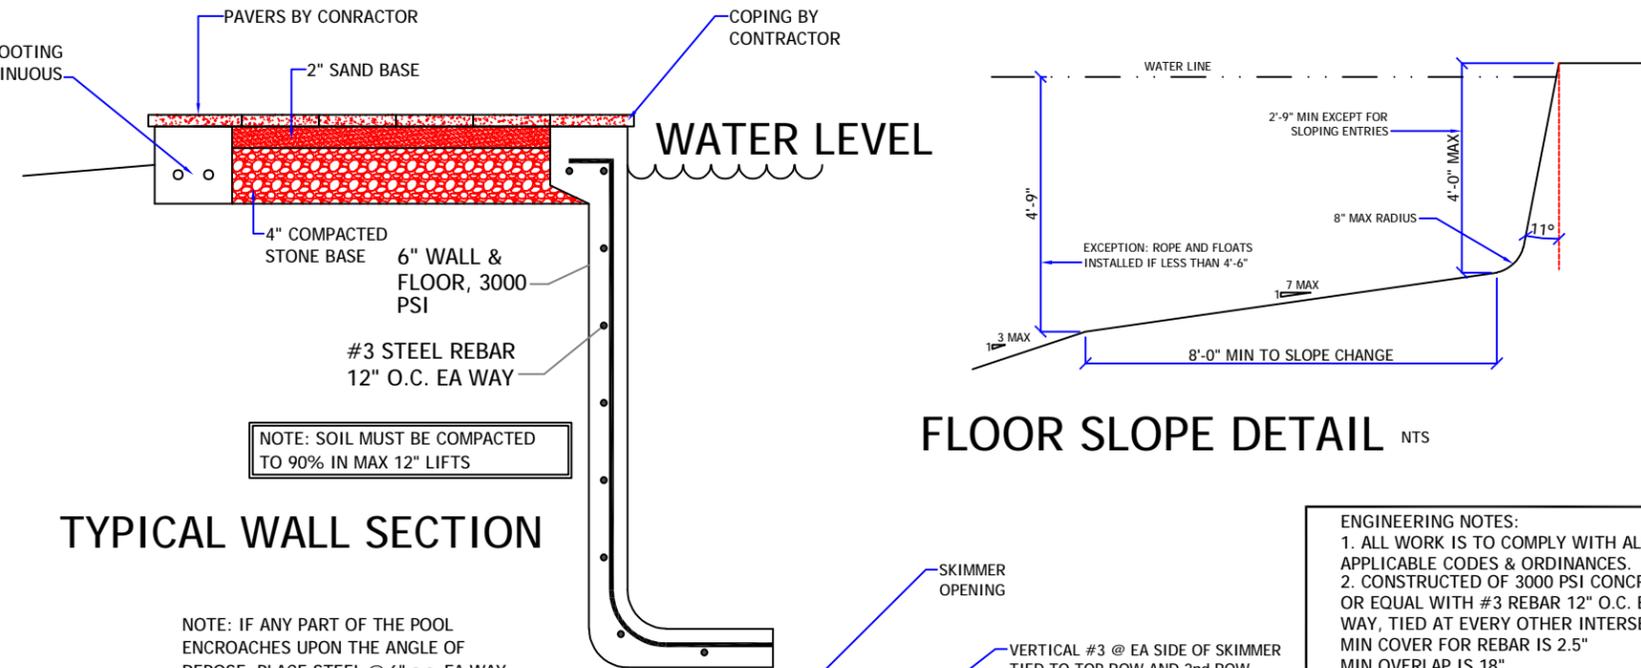


## TYPICAL WALL SECTION

NOTE: IF ANY PART OF THE POOL ENCROACHES UPON THE ANGLE OF REPOSE, PLACE STEEL @ 6" o.c. EA WAY IN AREAS OF QUESTION

NOTE: IF ANY PART OF THE POOL ENCROACHES UPON THE ANGLE OF REPOSE, PLACE STEEL @ 6" o.c. EA WAY IN AREAS OF QUESTION

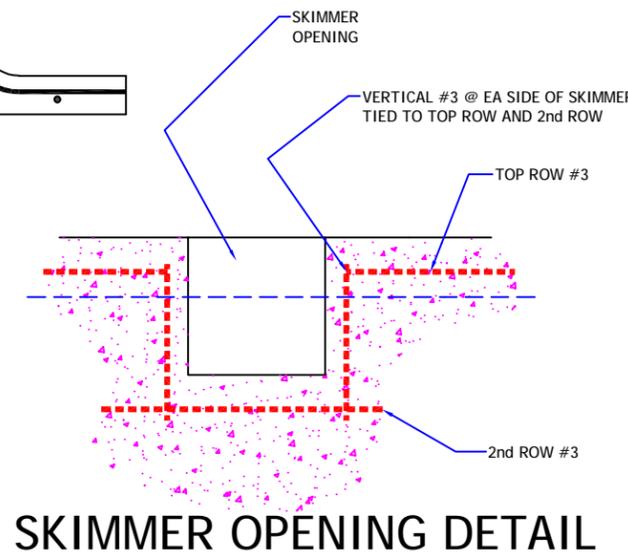

## SKIMMER OPENING DETAIL

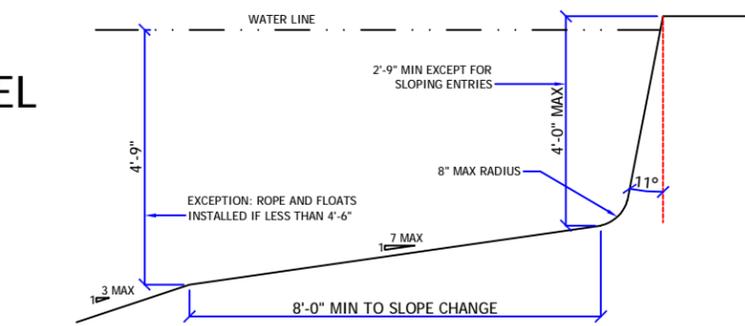

## FLOOR SLOPE DETAIL NTS

ENGINEERING NOTES:  
 1. ALL WORK IS TO COMPLY WITH ALL APPLICABLE CODES & ORDINANCES.  
 2. CONSTRUCTED OF 3000 PSI CONCRETE OR EQUAL WITH #3 REBAR 12" O.C. EACH WAY, TIED AT EVERY OTHER INTERSECTION. MIN COVER FOR REBAR IS 2.5" MIN OVERLAP IS 18".  
 3. N/A


4. ASSUMED SOIL BEARING = 2 KSF  
 5. CIRCULATION SYSTEMS, COMPONENTS, & EQUIPMENT SHALL COMPLY W/ NSF 50.  
 6. INSTALL CONTROL JOINTS @ 20'-0" ON CENTER IN POOL DECKING.  
 7. PLANS TO CONFORM TO NEC 2020  
 8. 2023 FBC RESIDENTIAL 8th EDITION APSP13  
 9. CONCRETE STAIRS ARE 12" TREAD WIDTH AND 10" MAXIMUM HEIGHT  
 10. ALL CONSTRUCTION SHALL COMPLY WITH ANSI 5-03, 2020 NEC ARTICLE 680, & ANSI-NSPI 3-99 IN-GROUND SPA CONSTR.

\*11. ENGINEERS DESIGN IS FOR STRUCTURAL ONLY. DESIGN OF PIPING/EQUIPMENT ETC.

BY POOL CONTRACTOR

### FENCE REQUIREMENTS:

1. MINIMUM 48" HEIGHT
2. 2" MAX VERTICAL CLEARANCE BETWEEN GRADE & BARRIER BOTTOM.
3. MAX OPENING SHALL NOT ALLOW PASSAGE OF 4" SPHERE.
4. FENCE POSTS WILL BE LOCATED ON POOL-SIDE OF FENCE.
5. GATE WILL BE SELF-LOCKING WITH APPROVED LOCKING DEVICE.

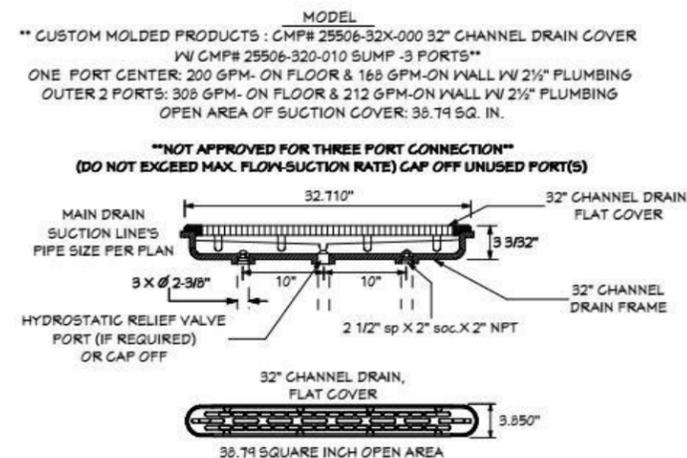

## Riddle Consulting Engineers, Inc.


structural  
civil  
mechanical

Paul D. Riddle, P.E.  
Senior Engineer  
COA: 00004759

ADDRESS 1720 SE CTY HWY 484  
BELLEVUE, FL 34420  
PHONE (352) 245-7041  
FAX (352) 245-5458  
WEB: WWW.RIDDLEENGINEERING.COM

ENGINEER'S SEAL

PAUL D. RIDDLE, P.E.  
P.E. 36989

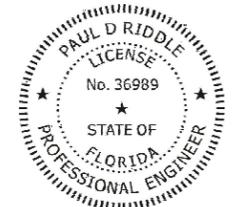

THIS ITEM HAS BEEN DIGITALLY SIGNED AND SEALED BY PAUL D. RIDDLE, PE ON THE DATE ADJACENT TO THE SEAL. PRINTED COPIES OF THIS DOCUMENT ARE NOT CONSIDERED SIGNED AND SEALED AND THE SIGNATURE MUST BE VERIFIED ON ANY ELECTRONIC COPIES.


JOB No.: 2250048

DATE Jan. 8, 26

A CUSTOM DESIGN FOR  
THE RICHARDSON  
RESIDENCE  
AQUATIC ART POOLS AND SPAS

Page:

1 of 4  
3/16" = 1'-0" SCALE

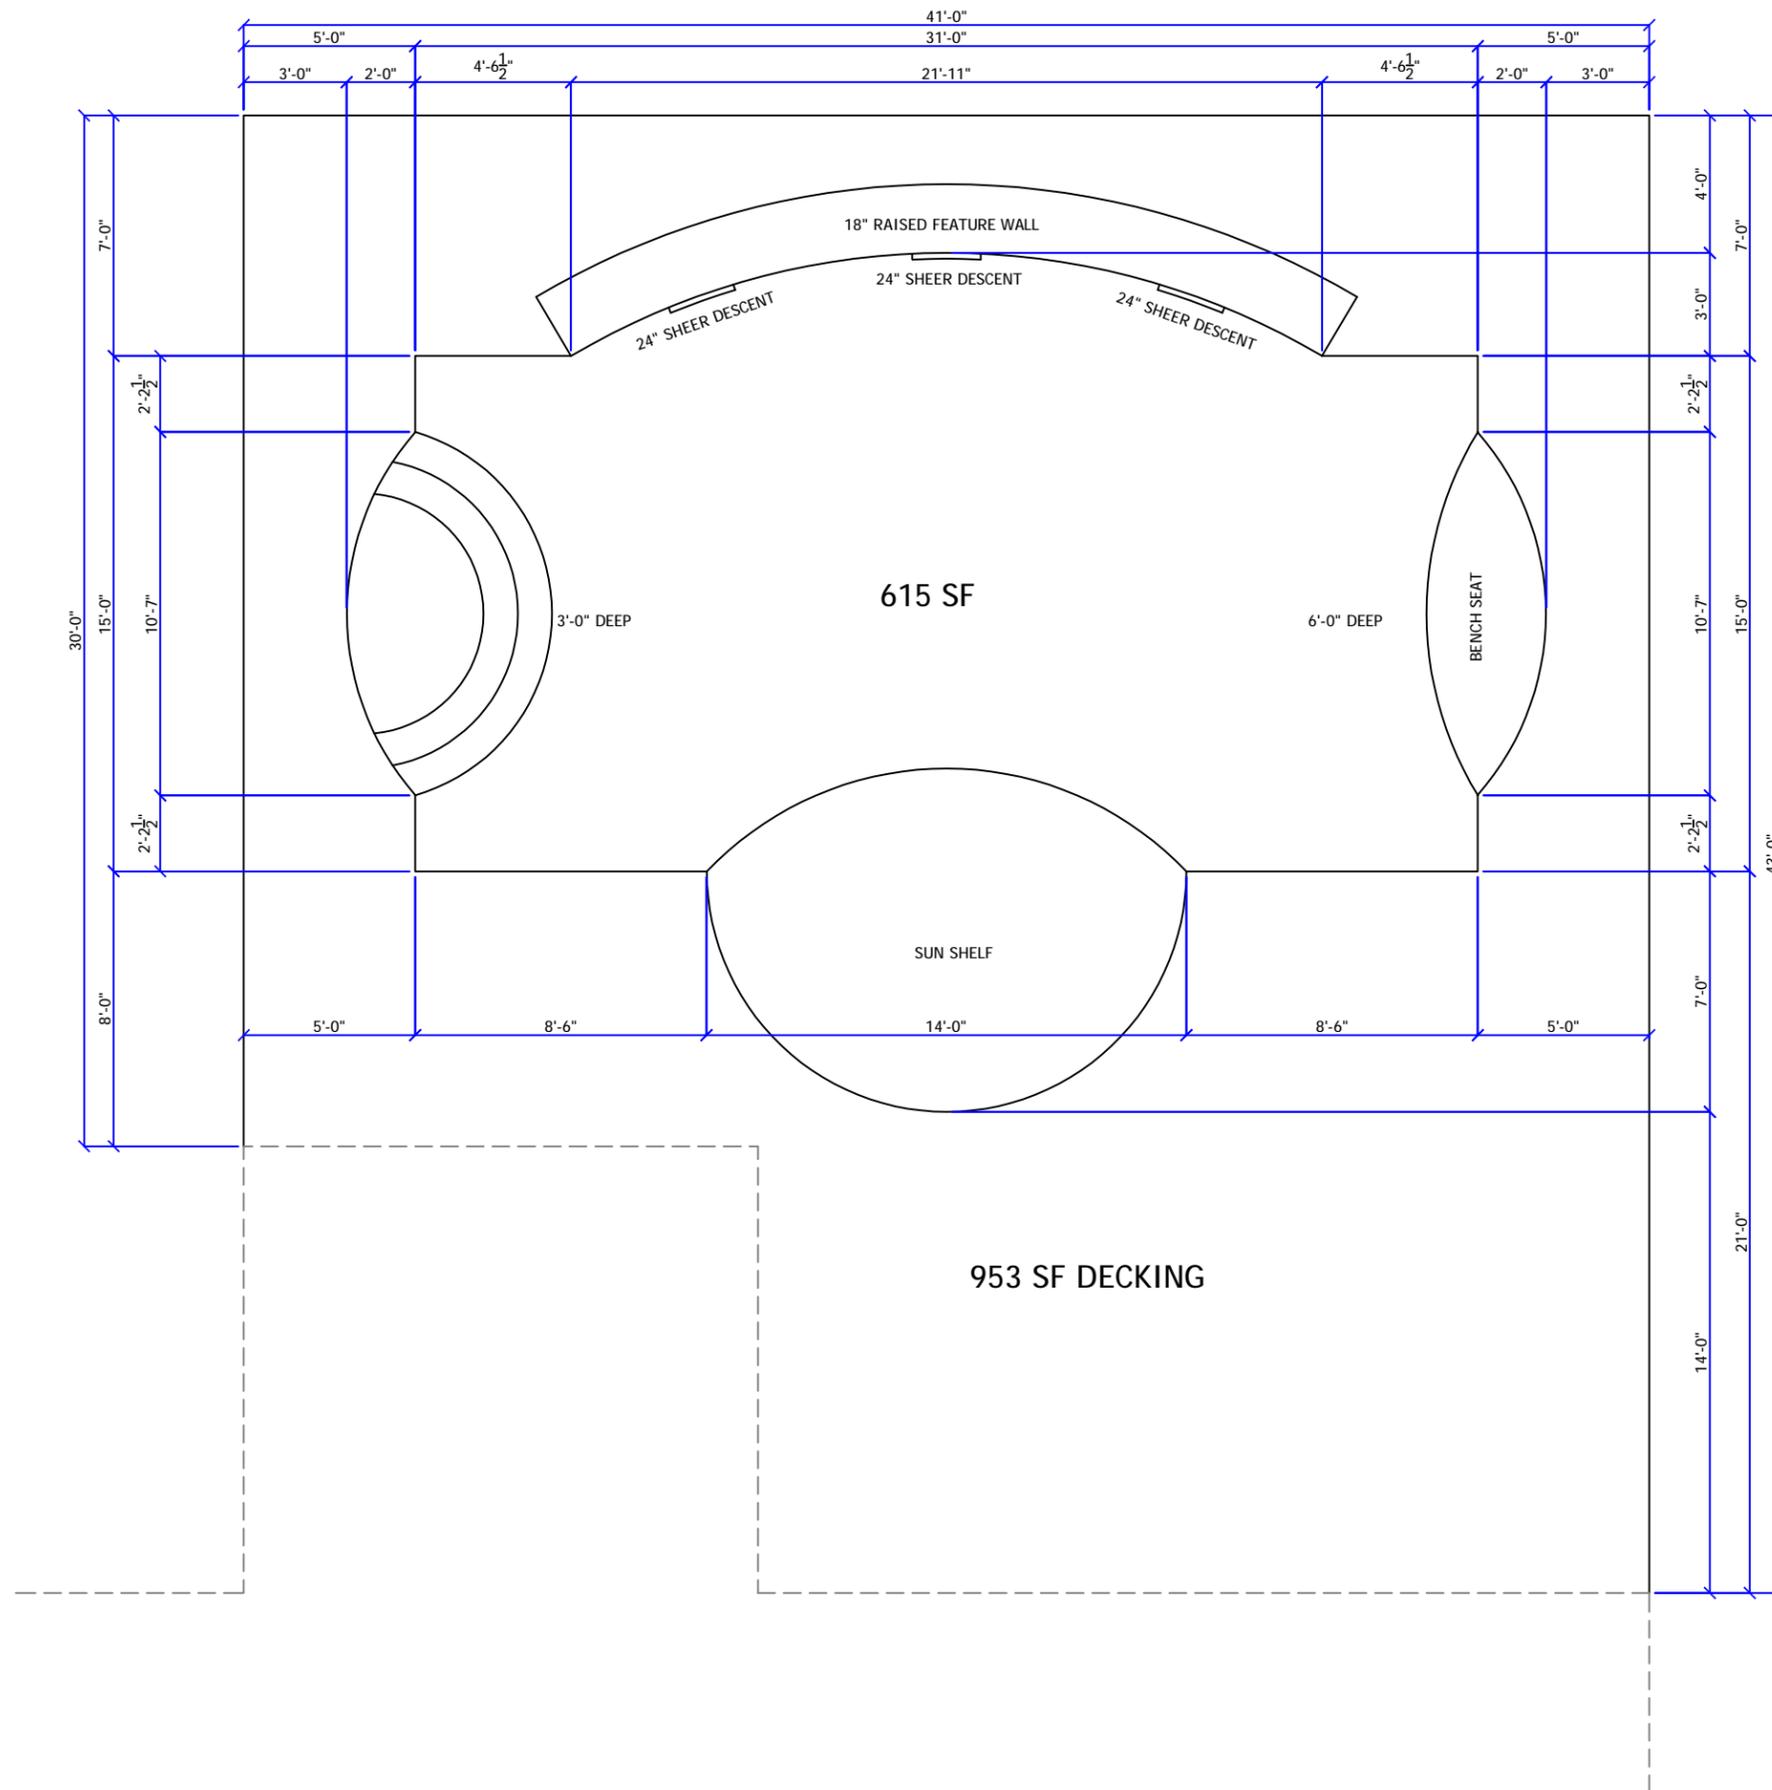

ENGINEER'S SEAL

PAUL D. RIDDLE, P.E.  
P.E. 36989





THIS ITEM HAS BEEN DIGITALLY SIGNED AND SEALED BY PAUL D. RIDDLE, PE ON THE DATE ADJACENT TO THE SEAL. PRINTED COPIES OF THIS DOCUMENT ARE NOT CONSIDERED SIGNED AND SEALED AND THE SIGNATURE MUST BE VERIFIED ON ANY ELECTRONIC COPIES.

JOB No.:

DATE Jan. 8, 26

A CUSTOM DESIGN FOR  
**THE RICHARDSON  
RESIDENCE**  
AQUATIC ART POOLS AND SPAS

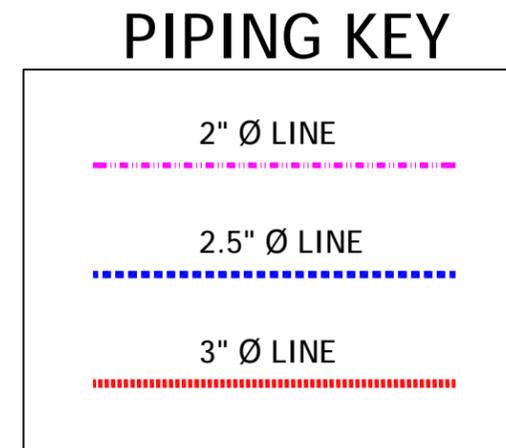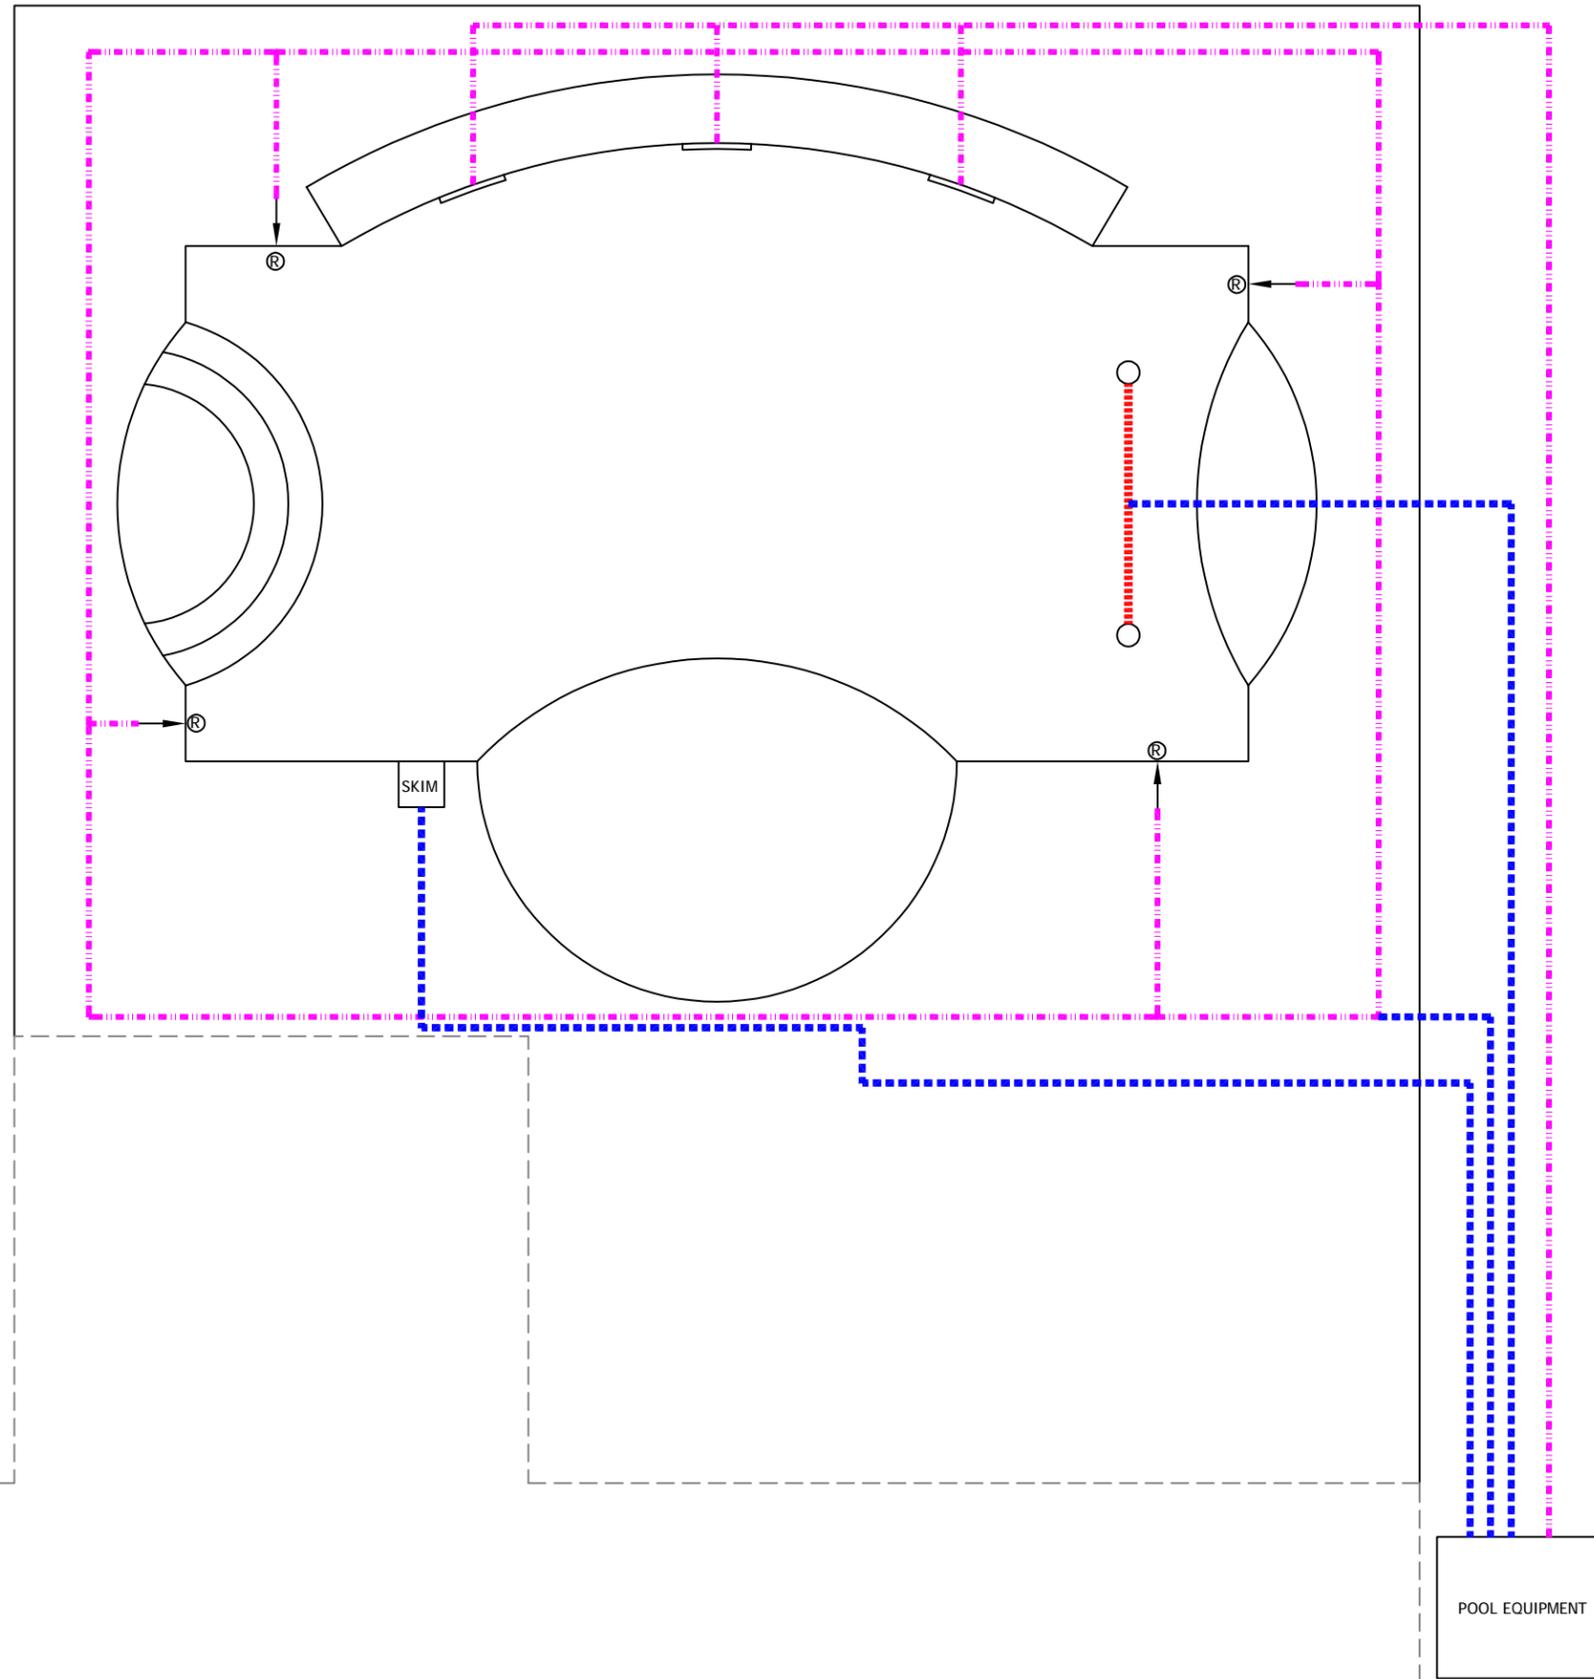

**Riddle Consulting Engineers, Inc.**

**structural  
civil  
mechanical**

Paul D. Riddle, P.E.  
Senior Engineer  
COA: 00004759

ADDRESS 1720 SE CTY HWY 484  
BELLEVUE, FL 34420

PHONE (352) 245-7041


FAX (352) 245-5458

WEB: [WWW.RIDDLEENGINEERING.COM](http://WWW.RIDDLEENGINEERING.COM)

ENGINEER'S SEAL

---

PAUL D. RIDDLE, P.E.  
P.E. 36989

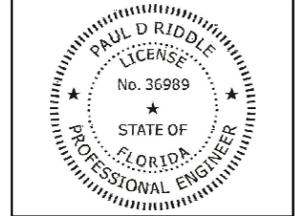

THIS ITEM HAS BEEN DIGITALLY SIGNED AND SEALED BY PAUL D. RIDDLE, PE ON THE DATE ADJACENT TO THE SEAL. PRINTED COPIES OF THIS DOCUMENT ARE NOT CONSIDERED SIGNED AND SEALED AND THE SIGNATURE MUST BE VERIFIED ON ANY ELECTRONIC COPIES.

JOB No.:


DATE Jan. 8, 26

A CUSTOM DESIGN FOR  
THE RICHARDSON  
RESIDENCE  
AQUATIC ART POOLS AND SPAS

## SPECIFICATIONS

Model No.	THP	WEF <sup>5</sup>	Voltage	Max Watts	Amps	Union Size	Rec. Pipe Size <sup>4</sup>	Carton Weight	Overall Length
VSFHP165JEP VSFHP165AUT	1.65	9.118	230VAC	1,600 W	10.5	2" x 2"	1 1/2 - 2 1/2"	46 lbs	24"
VSFHP085JEP VSFHP085AUT	0.85	11.900	115VAC	975 W	10.0	2" x 2"	1 1/2 - 2"	46 lbs	24"

## PERFORMANCE

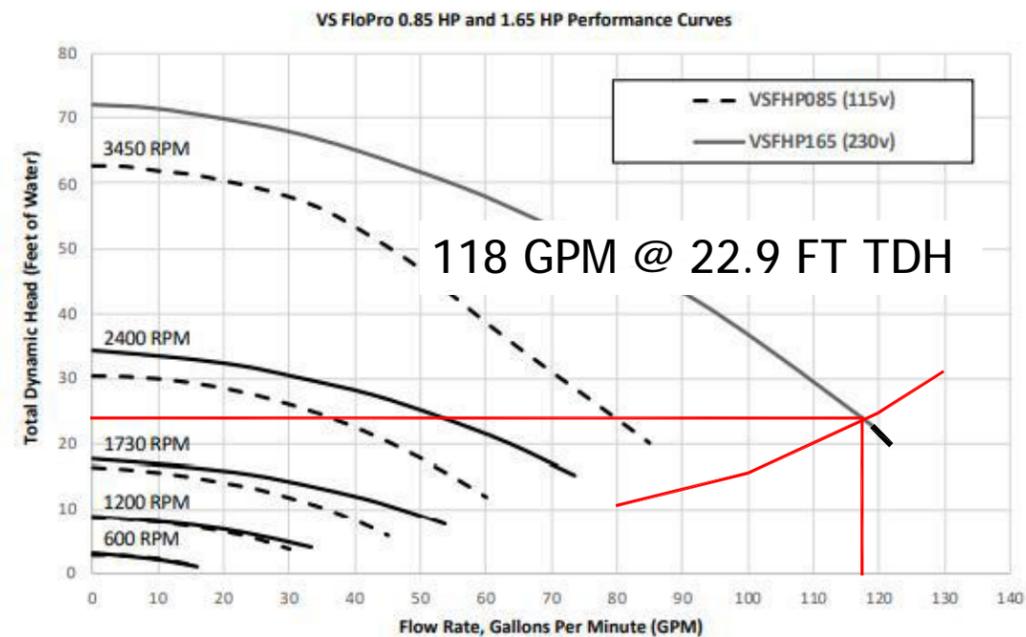

## AQUATIC ART

1/8/2026

MINIMUM FLOW REQ'D = 129.50 GPM  
 POOL VOLUME : SURFACE AREA X AVG DEPTH X 7.48 GAL / CF  
 VOL = **615** SF X **4.5** FT DEEP = **20700.9** Gallons  
 TURNOVER TIME: No. Hours X 60 min / ho e  
**6** hours x 60 = **360** minutes

MAX POOL FLOW RATE: GALLONS / TURNOVER = FLOW RATE  
 20700.9 GAL / 360 minutes = **57.5025** GPM

JETS, SHEER DE **3** WATER FEATURE GPM EA = **72** GPM  
 TOTAL SUGGESTED POOL FLOW RATE: **129.50** GPM

V = 1.318 C R<sup>0.63</sup> S<sup>0.54</sup>

### SUPPLY (RETURN) PIPING

**2.5** in = NOMINAL DIAMETER  
 2.45 in = D ACTUAL diam  
 0.2038 ft = D diam  
**140** = C, coefficient of roughness  
 4.6951 in<sup>2</sup> = A pipe  
 0.0326 ft<sup>2</sup> = A pipe  
**118.00** gpm / line = 0.2629234 cfs  
**118.00** gpm = TOTAL FLOW IN 1 LINES  
**0.2629** cfs = Q flow M  
 8.0639 f/sec = V = Velocity  
 0.0509 ft = R = Hydraulic Radius = A / P

0.0979 ft/ft = S hydraulic gradient  
**18** ft = pipe length average  
**1.76** ft = hf = head loss due to friction  
 0.76 psi 0.00763

### BRANCH P model

2 in @ 6 fps max BRANCH = 61.54 GPM  
 2 in @ 8 fps max TRUNK = 82.06 GPM  
 2 in @ 10 fps max RETURN = 102.57 GPM  
 3 in @ 3 fps max RETURN = 67.95 GPM MAIN

### SUCTION PIPING

**2.5** in = NOMINAL DIAMETER  
 2.45 in = D ACTUAL diam  
 0.2038 ft = D diam  
**140** = C, coefficient of roughness  
 4.6951 in<sup>2</sup> = A pipe  
 0.0326 ft<sup>2</sup> = A pipe  
**59.00** gpm = 0.1314617 cfs  
**2** No of Suction Pipes  
**0.1315** cfs = Q flow rate  
 4.0319 f/sec = V = Velocity  
 0.0509 ft = R = Hydraulic Radius = A / P

0.0271 ft/ft = S hydraulic gradient  
**46** ft = pipe length average  
**1.25** ft = hf = head loss due to friction  
 0.54 psi 0.0054019

	FT	PSI
	22.9	9.91373

### OTHER PRESSURE LOSSES

per mntg  
**6.98** FT = FILTER TDH LOSS  
 FT = HEATER TDH LOSS  
**6.98** FT = TOTAL TDH LOSS

### JANDY PRO SERIES CS150-250 CARTRIDGE FILTER

### MINOR LOSSES (SUPPLY & SUCTION COMBINED)

h (lost) = KL * V <sup>2</sup> / (2*g)	K	h (lost) ft
2 ea = # tees thru side outlet	1.75	3.53
2 ea = # gate valves	1	2.02
1 ea = # check valves	0.2	0.20
0 THERAPY JET	21.73	0.00
0 ea = # 45 deg ELL	0.4	0.00
6 ea = # 90 deg ELL	0.75	4.54
0 ea = Reducer D2=	0.5	0.0871791
<b>TOTAL =</b>		<b>10.30</b> ft

**PAUL D. RIDDLE**  
 P.E. No. 36989, FL  
 RIDDLE CONSULTING ENGINEERS  
 1720 SE COUNTY HWY 484  
 BELLEVIEW, FLORIDA 34420  
 CERT OF AUTH: 4759

### ELEVATION DIFFERENCE

**0.00** ft = delta Z

**2.62** FT = TOTAL FRICTION HEAD LOSS AFTER SPLIT @ LOOP  
**22.90** FT = TOTAL HEAD LOSS IN SYSTEM @ **118.00** GPM  
**9.91** PSI

PUMP SELECTION : **JANDY 1.65 VS PUMP**  
 model: **VARIABLE SPEED**

SUCTION OUTLET COVER: **MUST EXCEED 118.00 GPM FLOW RATE**  
 model **32" CHANNEL DRAIN OR 2 OUTLET COVERS**

SYSTEM FLOW RATE MUST NOT EXCEED APPROVED COVER FLOW RATE **O.K.**  
 PER FBC 2023 8TH EDITION ANSI / APSP 13  
**MOTOR TO BE GFCI PROTECTED PER NEC 680.21©**

## RICHARDSON

## Riddle Consulting Engineers, Inc.


structural  
civil  
mechanical

Paul D. Riddle, P.E.  
 Senior Engineer  
 COA: 00004759

ADDRESS 1720 SE CTY HWY 484  
 BELLEVIEW, FL 34420  
 PHONE (352) 245-7041  
 FAX (352) 245-5458  
 WEB: WWW.RIDDLEENGINEERING.COM

ENGINEER'S SEAL

PAUL D. RIDDLE, P.E.  
 P.E. 36989

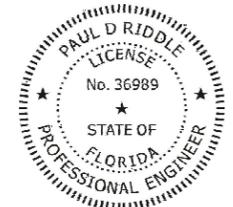

THIS ITEM HAS BEEN DIGITALLY SIGNED AND SEALED BY PAUL D. RIDDLE, PE ON THE DATE ADJACENT TO THE SEAL. PRINTED COPIES OF THIS DOCUMENT ARE NOT CONSIDERED SIGNED AND SEALED AND THE SIGNATURE MUST BE VERIFIED ON ANY ELECTRONIC COPIES.

JOB No.:

DATE Jan. 8, 26

A CUSTOM DESIGN FOR  
**THE RICHARDSON**  
**RESIDENCE**  
 AQUATIC ART POOLS AND SPAS

Page:

**4 of 4**

3/16" = 1'-0" SCALE