


FP	FIRE PROTECTION PLAN	SCOPE OF WORK INSALL NEW SPRINKLER SYSTEM	CONTRACT INFO	CONTRACTOR CONTACT NAME CONTACT # M.PERMIT #	THIS DOCUMENT IS THE PROPERTY OF CARIBBEAN FIRE & ASSOCIATES AND SHALL NOT BE REPRODUCED WITHOUT THE WRITTEN CONSENT OF CARIBBEAN FIRE & ASSOCIATES.	BY No.	REVISIONS	DATE	NO SCALE													Drawn OF Check SS	Drawing No. FP-1 1 of 2
									MAXIMUM DISTANCE BETWEEN HANGERS														
									Job No. 5265 Date 09/28/20														
1/8"=1'-0"	OCCUPANCY:LIGHT/ORDINARY HAZARD								NOMINAL PIPE SIZE (in.)	3/4"	1"	1-1/4"	1-1/2"	2"	2-1/2"	3"	3-1/2"	4"	5"	6"	8"		
									STEEL PIPE EXCEPT THREADED LIGHTWALL	N/A	12-0	12-0	15-0	15-0	15-0	15-0	15-0	15-0	15-0	15-0	15-0		
									THREADED LIGHTWALL STEEL PIPE	N/A	12-0	12-0	12-0	12-0	12-0	12-0	N/A	N/A	N/A	N/A	N/A	N/A	
										5-6	6-0	6-6	2-0	8-0	6-0	12-0	N/A	N/A	N/A	N/A	N/A		

SCALE: $1/8" = 1'-0"$

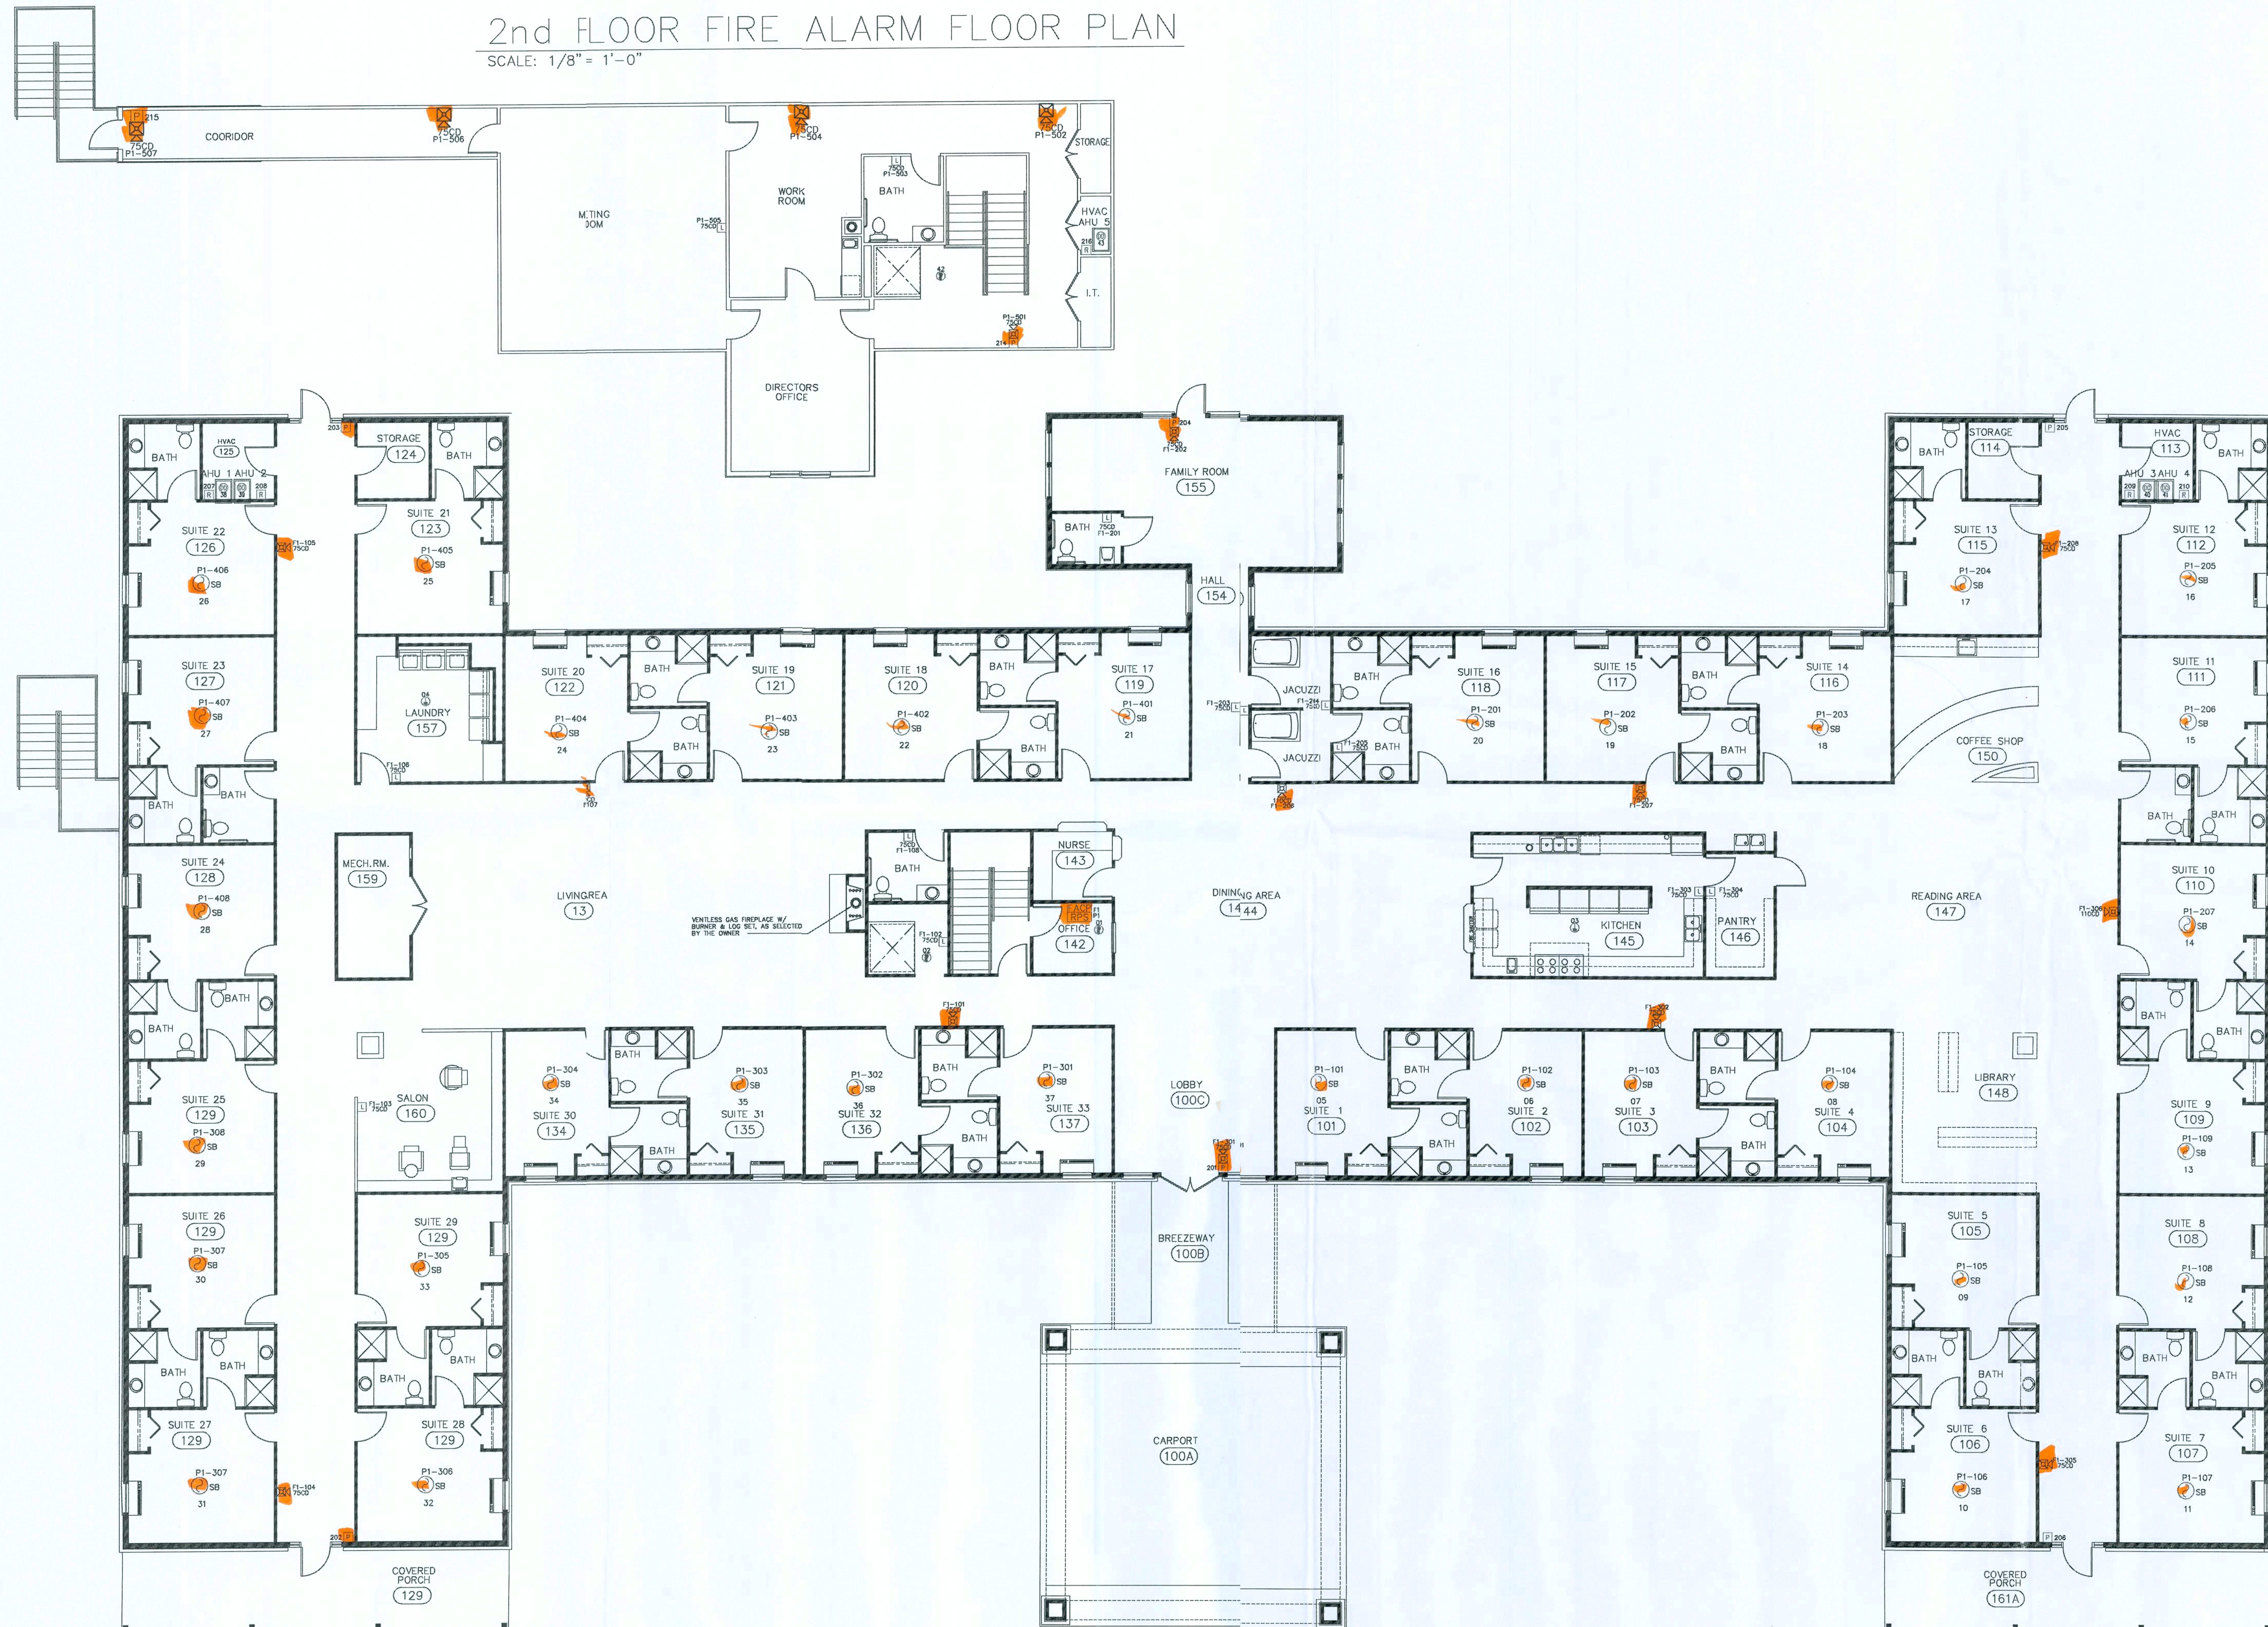

SCALE: $1/8" = 1'-0"$

APPROVED (Subject to Revisions)
Life Safety Services
Columbia County Fire Rescue
Florida State Fire Inspector # 136416
By: [Signature] Date: 10/9/2020


SMITH - SORENSON
LAKE CITY, FLORIDA 32055

PROJECT


DRAWING TYPE

FIRE ALARM
PLAN

CARIBBEAN FIRE & SECURITY, INC.
3856 S.W. 30th AVE.
HOLLYWOOD, FLORIDA 33312
(954)581-9393 FAX:(954)581-2896

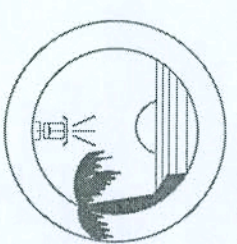

Important: This material is the property of Corbenn Fire & Security, Inc. and is loaned for review and evaluation purposes only. It is confidential as such, it is subject to recall at any time and is not to be disclosed or transmitted to other parties nor copied in any form without the prior written consent of Corbenn Fire & Security, Inc.

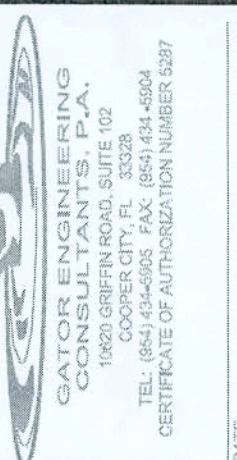

DWG #: 0928-81F-0703

REVISION: 0


DATE: 09/28/2020

SCALE: $1/8"=1'-0"$

DRAWN BY F.O.

CHECKED BY S.P.

SHEET FA-1 OF 3

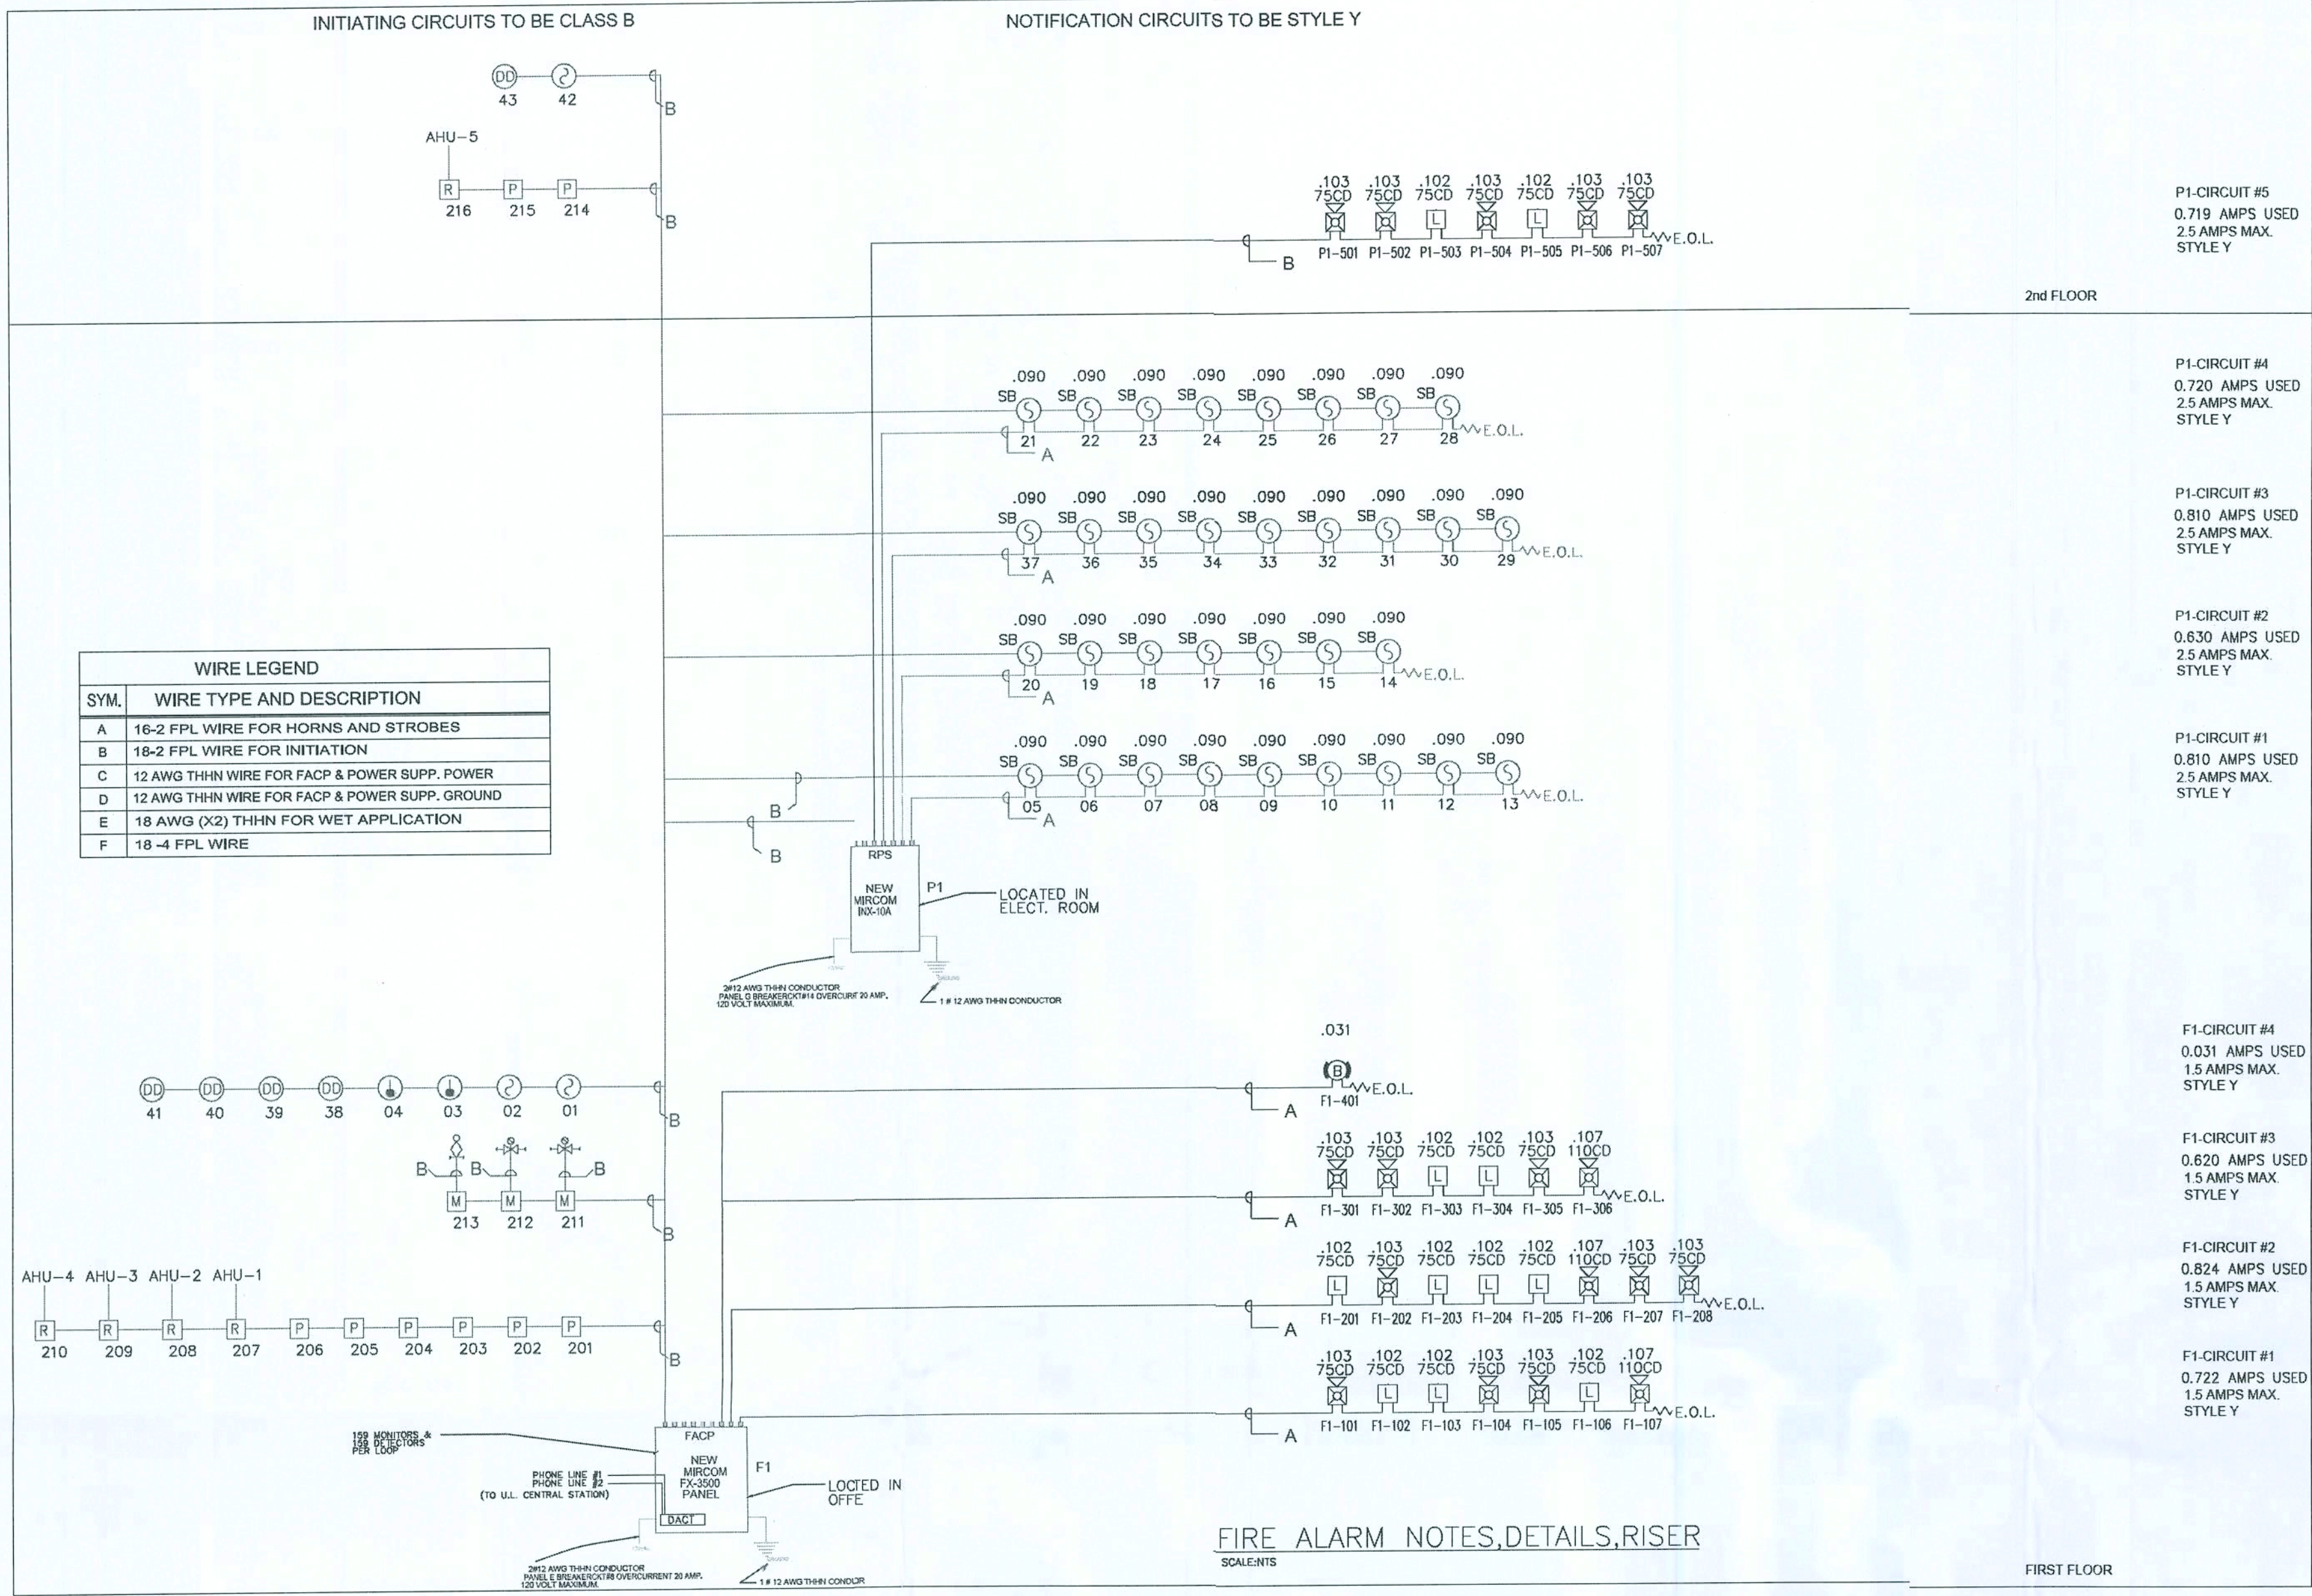

MIRCOM FX-3500-BATTERY CALCULATIONS						F1
	CD	QTY	STANDBY PER DEV.	TOTAL STANDBY	ALARM PER DEV.	TOTAL ALARM
FIRE ALARM PANEL		1	0.390000	0.390000	0.630000	0.630000
MIX-225TAP SMOKE DETECTOR		37	0.000300	0.011100	0.006500	0.240500
MIX-700AP PULL STATION		8	0.000400	0.003200	0.000600	0.004800
DNH W/MIX-225TAP SMOKE DETECTOR		5	0.000300	0.001500	0.000500	0.002500
MIX-M501MAP MONITOR MODULE		3	0.000400	0.001200	0.000600	0.001800
MIX-M500RAP RELAY MODULE		5	0.000300	0.001500	0.000500	0.002500
RAM-3500-LCD REMOTE ANNUNCIATOR		1	0.070000	0.070000	0.100000	0.100000
			TOTAL INPUT:		1.058	
CIRCUIT #1 1.5 Amps Max.						
WALL MOUNT STROBE	75	3	N/A	N/A	0.102	0.308
WALL MOUNT HORN/STROBE	75	3	N/A	N/A	0.103	0.309
WALL MOUNT HORN/STROBE	110	1	N/A	N/A	0.107	0.107
			TOTAL CIRCUIT #1:		0.722	
CIRCUIT #2 1.5 Amps Max.						
WALL MOUNT STROBE	110	1	N/A	N/A	0.107	0.107
WALL MOUNT STROBE	75	4	N/A	N/A	0.102	0.408
WALL MOUNT HORN/STROBE	75	3	N/A	N/A	0.103	0.309
			TOTAL CIRCUIT #2:		0.824	
CIRCUIT #3 1.5 Amps Max.						
WALL MOUNT STROBE	75	2	N/A	N/A	0.102	0.204
WALL MOUNT HORN/STROBE	75	3	N/A	N/A	0.103	0.309
WALL MOUNT HORN/STROBE	110	1	N/A	N/A	0.107	0.107
			TOTAL CIRCUIT #3:		0.620	
CIRCUIT #4 1.5 Amps Max.						
MOTORIZED BELL	N/A	1	N/A	N/A	0.031	0.031
			TOTAL CIRCUIT #4:		0.031	
(A) TOTAL STANDBY			0.479		ALARM	
(B) STANDBY HOURS (24 OR 60):			24			
(C) TOTAL STANDBY AMP HOURS:			11.488			
(D) ALARM SOUNDING PERIOD IN MINUTES (5 OR 15):			5 MINUTES = 0.083 HOURS			
TOTAL ALARM X 0.083 = (E) TOTAL ALARM AMP HOURS:			0.270			
(F) TOTAL ALARM + STANDBY AH:			11.768			
MULT. BY DERATING FACTOR - 1.2:			14.119			
QTY-2 REQUIRED			MINIMUM 15 AH BATTERY PROVIDED CHARGE CAPACITY IS 26 AH			

MIRCOM INX-10A BATTERY CALCULATIONS						P1
	CD	QTY	STANDBY PER DEV.	TOTAL STANDBY	ALARM PER DEV.	TOTAL ALARM
MAIN PANEL		1	0.200	0.200	0.350	0.350
CIRCUIT #1 2.5 Amps Max.						
SOUNDER BASE	N/A	9	0.001	0.009	0.090	0.810
WALL MOUNT STROBE	75	0	N/A	N/A	0.102	0.000
WALL MOUNT HORN/STROBE	75	0	N/A	N/A	0.103	0.000
			TOTAL CIRCUIT #1:		0.810	
CIRCUIT #2 2.5 Amps Max.						
SOUNDER BASE	N/A	7	0.001	0.007	0.090	0.630
WALL MOUNT STROBE	75	0	N/A	N/A	0.102	0.000
WALL MOUNT HORN/STROBE	75	0	N/A	N/A	0.103	0.000
			TOTAL CIRCUIT #2:		0.630	
CIRCUIT #3 2.5 Amps Max.						
SOUNDER BASE	N/A	9	0.001	0.009	0.090	0.810
WALL MOUNT STROBE	75	0	N/A	N/A	0.102	0.000
WALL MOUNT HORN/STROBE	75	0	N/A	N/A	0.103	0.000
			TOTAL CIRCUIT #3:		0.810	
CIRCUIT #4 2.5 Amps Max.						
SOUNDER BASE	N/A	8	0.001	0.008	0.090	0.720
WALL MOUNT STROBE	75	0	N/A	N/A	0.102	0.000
WALL MOUNT HORN/STROBE	75	0	N/A	N/A	0.103	0.000
			TOTAL CIRCUIT #4:		0.720	
CIRCUIT #5 2.5 Amps Max.						
SOUNDER BASE	N/A	0	0.001	0.000	0.090	0.000
WALL MOUNT STROBE	75	2	N/A	N/A	0.102	0.204
WALL MOUNT HORN/STROBE	75	5	N/A	N/A	0.103	0.515
			TOTAL CIRCUIT #5:		0.719	
CIRCUIT #6 2.5 Amps Max. (SPARE)						
SOUNDER BASE	N/A	0	0.001	0.000	0.090	0.000
WALL MOUNT STROBE	75	0	N/A	N/A	0.102	0.000
WALL MOUNT HORN/STROBE	75	0	N/A	N/A	0.103	0.000
			TOTAL CIRCUIT #6:		0.000	
(A) TOTAL STANDBY			0.224		ALARM	
(B) STANDBY HOURS (24 OR 60):			24			
(C) TOTAL STANDBY AMP HOURS:			5.376			
(D) ALARM SOUNDING PERIOD IN MINUTES (5 OR 15):			5 MINUTES = 0.083 HOURS			
TOTAL ALARM X 0.083 = (E) TOTAL ALARM AMP HOURS:			0.335			
(F) TOTAL ALARM + STANDBY AH:			5.711			
MULT. BY DERATING FACTOR - 1.2:			6.853			
QTY-2 REQUIRED			MINIMUM 7.0 AH BATTERY PROVIDED CHARGE CAPACITY IS 18 AH			

N.A.C. VOLTAGE DROP CALCULATIONS						F1
DC RESISTANCE FOR SOLID COPPER WIRE AT 75 DEGREES -C			NAC #1		WIRE SIZE	
SIZE			R _c		16	
18			L _c		0.00489	
16			L _c		0.81	
14			V _D		1.48	
12			V _D		16.92	
10			V _D		7.289	
VALUES TAKEN FROM 2011 NEC CHAPTER 9 TABLE 8			NAC #2		WIRE SIZE	
FORMULA FOR CALCULATION OF VOLTAGE DROP IN DC 2 WIRE CIRCUITS			R _c		0.00489	
V _D = R _c X I X L			L _c		0.81	
WHERE V _D = VOLTAGE DROP AT THE LAST DEVICE ON THE CIRCUIT			V _D		1.48	
"R _c " = RESISTANCE OF WIRE IN OHMS PER FOOT (VALUES OF RESISTANCE FOR COPPER WIRE PER TABLE ABOVE)			NAC #3		WIRE SIZE	
"I" = TOTAL CIRCUIT CURRENT IN AMPERES			R _c		0.00489	
"L" = LENGTH ONE WAY OF THE CIRCUIT IN FEET			L _c		0.81	
STARTING VOLTAGE USED IN CALCULATIONS IS 20.4 PER U.L. & NFPA REQUIREMENTS			V _D		1.32758	
(INFORMATION PROVIDED BY CUSTOMER)			NAC #4		WIRE SIZE	
			R _c		0.00489	
			L _c		0.81	
			V _D		1.48	
			V _D		16.92	
			V _D		7.289	

N.A.C. VOLTAGE DROP CALCULATIONS						P1
DC RESISTANCE FOR SOLID COPPER WIRE AT 75 DEGREES -C			NAC #1		WIRE SIZE	
SIZE			R _c		16	
18			L _c		0.00489	
16			L _c		0.81	
14			V _D		1.48	
12			V _D		16.92	
10			V _D		7.289	
VALUES TAKEN FROM 2011 NEC CHAPTER 9 TABLE 8			NAC #2		WIRE SIZE	
FORMULA FOR CALCULATION OF VOLTAGE DROP IN DC 2 WIRE CIRCUITS			R _c		0.00489	
V _D = R _c X I X L			L _c		0.81	
WHERE V _D = VOLTAGE DROP AT THE LAST DEVICE ON THE CIRCUIT			NAC #3		WIRE SIZE	
"R _c " = RESISTANCE OF WIRE IN OHMS PER FOOT (VALUES OF RESISTANCE FOR COPPER WIRE PER TABLE ABOVE)			R _c		0.00489	
"I" = TOTAL CIRCUIT CURRENT IN AMPERES			L _c		0.81	
"L" = LENGTH ONE WAY OF THE CIRCUIT IN FEET			V _D		1.48	
STARTING VOLTAGE USED IN CALCULATIONS IS 20.4 PER U.L. & NFPA REQUIREMENTS			NAC #4		WIRE SIZE	
(INFORMATION PROVIDED BY CUSTOMER)			R _c		0.00489	
			L _c		0.81	
			V _D		1.48	
			V _D		16.92	
			V _D		7.289	

FIRE ALARM GENERAL NOTES:

- NEW MIRCOM FX-3500 FIRE ALARM PANEL TO BE POWER LIMITED AND HAVE BATTERY BACKUP.
- BUILDING IS NEW.
- BUILDING IS 100% SPRINKLERED.
- OCCUPANCY: ASSISTED LIVING FACILITY
- SYSTEM AND INSTALLATION TO COMPLY WITH FLORIDA FIRE PREVENTION SIXTH EDITION, NFPA-72 2013 EDITION, NFPA-1 2015, AND NFPA-101 2015 EDITION, NFPA-70 2014 EDITION.
- WIRING MINIMUMS:
 - INITIATING CIRCUITS 18/2 FPL
 - INDICATING CIRCUITS 16/2 FPL (NAC)
 - SOUNDER BASES 16/2 FPL
- CONDUIT IF REQUIRED WILL BE 1/2", MINIMUM 40% FILL MAX.
- ALL DEVICES TO BE MOUNTED PER NFPA GUIDELINES OR ADA WHERE REQUIRED.
- SYSTEM COMPONENTS SHALL BE U.L. LISTED AND COMPATIBLE
- CIRCUITS TO BE CLASS B.
- WHERE AUDIBLE APPLIANCES ARE INSTALLED TO PROVIDE SIGNALS FOR SLEEPING AREAS, THEY SHALL HAVE A SOUND LEVEL OF AT LEAST 15dB ABOVE THE AVERAGE AMBIENT SOUND LEVEL OR 5dB ABOVE THE MAXIMUM SOUND LEVEL HAVING A DURATION OF AT LEAST 60 SECONDS OR A SOUND LEVEL OF AT LEAST 75dB, WHICHEVER IS GREATER, MEASURED AT THE PILLOW LEVEL IN THE OCCUPIABLE AREA, USING THE A-WEIGHTED SCALE (dBA).
- AUDIBLE RATINGS, AS MEASURED BY THE MANUFACTURER AND THE QUALIFIED TESTING LABS, ARE SPECIFIED AS A DECIBEL RATING AT A PREDETERMINED DISTANCE, USUALLY 10 FT. THE RULE OF THUMB IS THAT THE OUTPUT OF AN AUDIBLE NOTIFICATION APPLIANCE IS REDUCED BY 6dB IF THE DISTANCE BETWEEN THE APPLIANCE AND LISTENER IS DOUBLED.
- EACH STROBE SHALL BE ADEQUATE TO PROVIDE REQUIRED COVERAGE.
- THE DESIGN INSTALLATION COMPLIES WITH FBC 2017.

SCOPE OF WORK:

- INSTALL NEW ADDRESSABLE MIRCOM FX-3500 FIRE ALARM PANEL AT REFERENCED PROPERTY.
 - SCOPE OF WORK IS LIMITED ONLY TO WHAT IS PROVIDED ON FLOOR PLAN AND RISER.
 - FIRE ALARM CONTROL PANEL & POWER BOOSTER TO BE PROTECTED BY SMOKE DETECTOR.
 - INSTALL PULL STATIONS AT EXITS.
 - INSTALL HORN/STROBES AND STROBES THROUGHOUT.
 - INSTALLS SMOKE DETECTORS WITH LOW FREQUENCY SOUNDBASES IN ALL SLEEPING UNITS.
 - AUDIBLE TROUBLE SIGNAL TO BE LOCATED AT FACP AND ANNUNCIATOR.
 - SYSTEM SHALL BE A REMOTE SUPERVISING STATION WITH 24 HOURS OF STANDBY.
1. ALL TAMPER SWITCHES (VALVE SUPERVISORY SWITCHES) SHALL INITIATE A SUPERVISORY SIGNAL INDICATING AN OFF-NORMAL CONDITION OF THE VALVE AT THE FIRE ALARM CONTROL PANEL AND THE U.L. CENTRAL STATION.
2. THE ACTUATION OF ANY FLOW SWITCH SHALL INITIATE AN ALARM SIGNAL AT THE FIRE ALARM CONTROL PANEL AND U.L. CENTRAL STATION, AND INITIATE THE SMOKE CONTROL FUNCTIONS FOR THE RELATED ZONE IN ALARM.

SEQUENCE OF OPERATION:


1. THE ACTUATION OF THE FIRE ALARM INITIATING DEVICE SHALL AUTOMATICALLY INITIATE THE FUNCTION DETAILED BELOW.
- A. MANUAL FIRE ALARM PULL STATION
- ACTIVATION OF THE MANUAL FIRE ALARM PULL STATION SHALL INITIATE THE FOLLOWING FUNCTIONS:
 - 1. GENERATE AN AUDIBLE SIGNAL AT FIRE ALARM CONTROL PANEL.
 - 2. GENERATE AN AUDIBLE ALARM SIGNAL SIMULTANEOUSLY ON DESIGNATED AREAS OF THE BUILDING BY MEANS OF A HORN/STROBE OR SOUNDER BASE DEVICE. GENERATE A VISUAL ALARM SIGNAL SIMULTANEOUSLY ON ALL AREAS OF THE BUILDING BY THE USE OF STROBE DEVICE OR COMBINATION HORN/STROBE NOTIFICATION DEVICES.
 - 3. INDICATE THE LOCATION OF THE PULL STATION, BY DISPLAYING IN ENGLISH THE ALARMED DEVICE AND ITS LOCATION ON THE FACP AND REMOTE ANNUNCIATOR DISPLAY.
 - 4. WHEN ALARMED, TRANSMITS A FIRE ALARM SIGNAL TO THE U.L. CENTRAL STATION.
- B. COMMON AREA SMOKE DETECTOR/HEAT DETECTOR
- ACTIVATION OF THE SMOKE DETECTORS SHALL INITIATE THE FOLLOWING FUNCTIONS:
 - 1. GENERATE AN AUDIBLE SIGNAL AT FIRE ALARM CONTROL PANEL.
 - 2. GENERATE AN AUDIBLE ALARM SIGNAL SIMULTANEOUSLY ON DESIGNATED AREAS OF THE BUILDING BY MEANS OF A HORN/STROBE OR SOUNDER BASE DEVICE. GENERATE A VISUAL ALARM SIGNAL SIMULTANEOUSLY ON ALL AREAS OF THE BUILDING BY THE USE OF STROBE DEVICES OR COMBINATION HORN/STROBE NOTIFICATION DEVICES.
 - 3. INDICATE THE LOCATION OF THE SMOKE DETECTOR, BY DISPLAYING IN ENGLISH THE ALARMED DEVICE AND ITS LOCATION ON THE FACP AND REMOTE ANNUNCIATOR DISPLAY.
 - 4. WHEN ALARMED, TRANSMITS A FIRE ALARM SIGNAL TO THE U.L. CENTRAL STATION.
- C. SLEEPING AREA SMOKE DETECTOR
- ACTIVATION OF THE SMOKE DETECTORS SHALL INITIATE THE FOLLOWING FUNCTIONS:
 - 1. GENERATE AN SUPERVISORY SIGNAL AT FIRE ALARM CONTROL PANEL.
 - 2. GENERATE AN AUDIBLE ALARM SIGNAL AT THAT UNIT BY MEANS OF THE SOUNDER BASE DEVICE.
 - 3. INDICATE THE LOCATION OF THE SMOKE DETECTOR, BY DISPLAYING IN ENGLISH THE ALARMED DEVICE AND ITS LOCATION ON THE FACP AND REMOTE ANNUNCIATOR DISPLAY.
 - 4. WHEN ALARMED, TRANSMITS A SUPERVISORY SIGNAL TO THE U.L. CENTRAL STATION.
- D. TROUBLE SIGNAL
1. TROUBLE AND SUPERVISORY DEVICES SHALL NOT ACTIVATE AUDIBLE AND VISIBLE DEVICES, INSTEAD THEY SHOULD SHOW A SUPERVISORY OR TROUBLE INDICATION AT FACP AND REMOTE ANNUNCIATOR IF INSTALLED. A TROUBLE SIGNAL COULD INDICATE A BREAK IN THE CIRCUIT WIRING OR A DETECTOR THAT IS



WL1147

1 OR 2 HOUR FIRE RATED THROUGH
PENETRATION FIRESTOP FOR SINGLE
METAL PIPE THROUGH GYPSUM
WALLS USING TREMSTOP WBM.

F-RATING = 1 AND 2 HR.
T-RATING = 0 AND 1/2 HR.

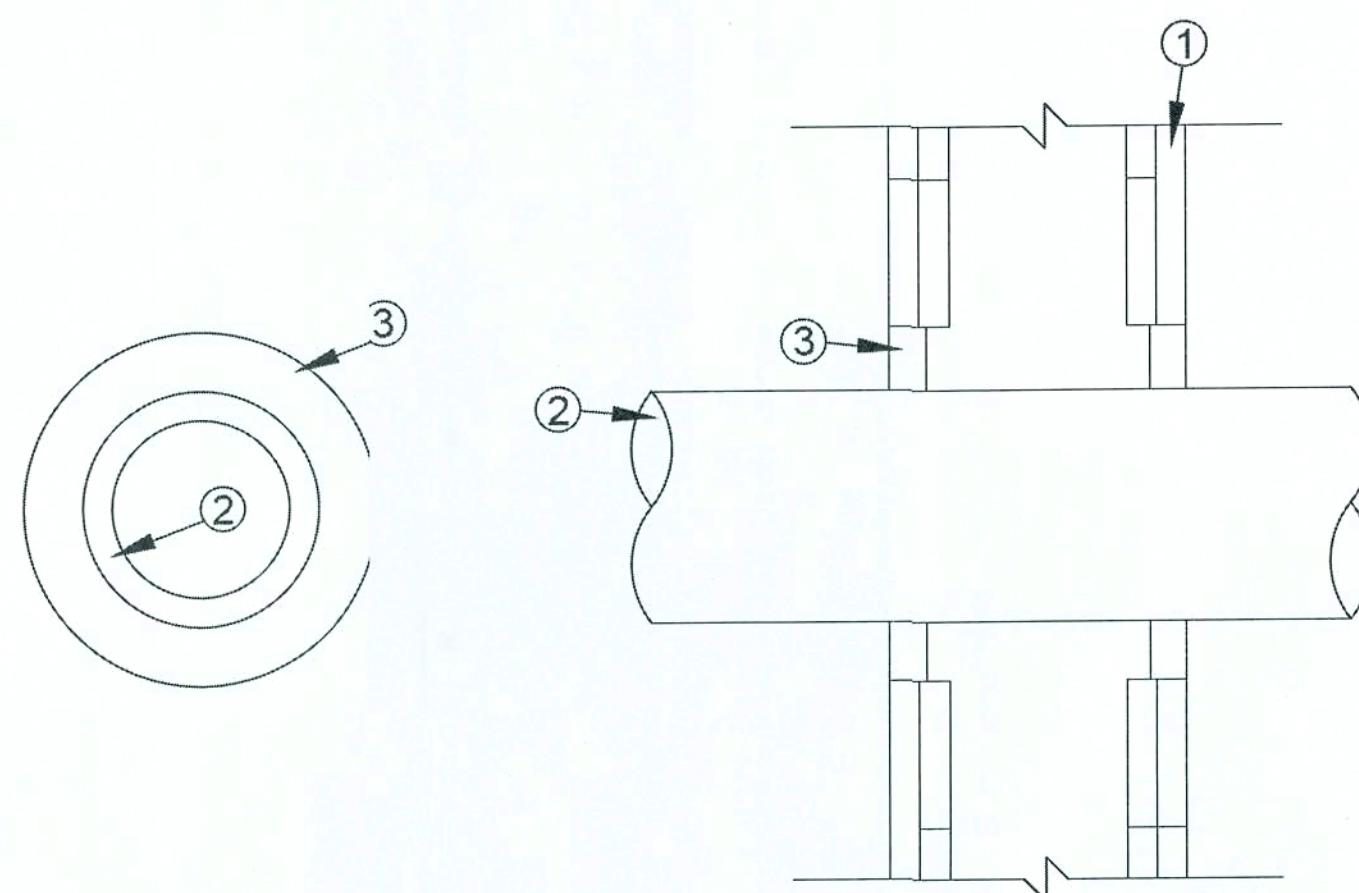


1. 1 OR 2 - HOUR FIRE RATED GYPSUM WALLBOARD/STUD ASSEMBLY
2. A) STEEL PIPE - 6" DIA.(OR SMALLER) SCH. 40 (OR HEAVIER) STEEL
B) CONDUIT - 4" DIA.(OR SMALLER) EMT OR RIGID STEEL
3. TREMSTOP WBM - FILL MAX. 3/4" ANNULUS AT A THICKNESS
OF 1" (2 HR. F-RATING) OR 3/4" (1 HR. F-RATING).



CAJ-1304

2 HOUR FIRE RATED THROUGH
PENETRATION FIRESTOP FOR
MULTIPLE METAL PIPE THROUGH
CONCRETE FLOORS OR WALLS
USING FYRE-SHIELD.

F-RATING = 2 HR.
T-RATING = 0 HR.

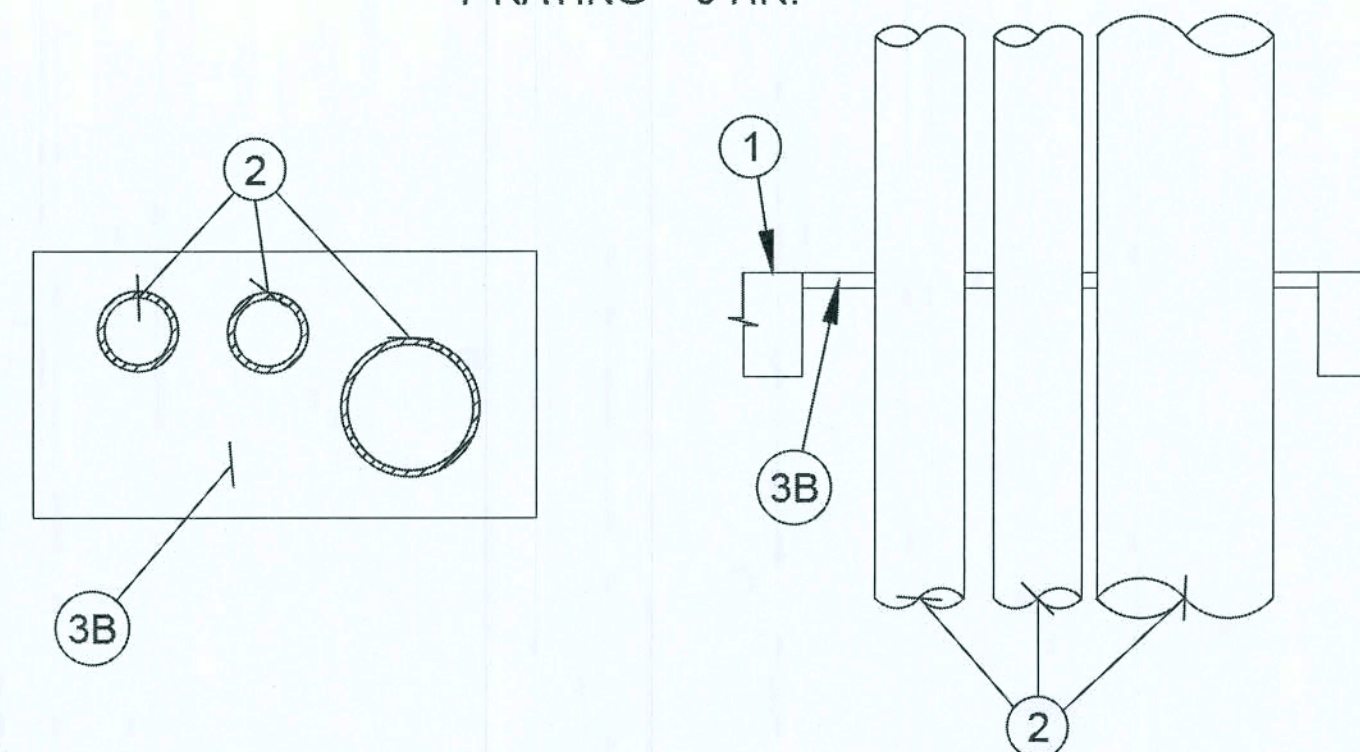

1. FLOOR OR WALL ASSEMBLY = 4" THICK CONCRETE, MAX.
AREA OF OPENING IS 288 SQ. IN.
2. COPPER PIPE: 4" DIA. (OR SMALLER) REGULAR (OR HEAVIER) COPPER.
STEEL PIPE: 8" DIA. (OR SMALLER) SCH.40 (OR HEAVIER) STEEL.
CONDUIT: 4" DIA. (OR SMALLER) EMT OR 6" DIA. (OR SMALLER) STEEL CONDUIT.
COPPER TUBING: 4" DIA.(OR SMALLER) TYPE L(OR HEAVIER) COPPER.
IRON PIPE: 8" DIA.(OR SMALLER) CAST OR DUCTILE IRON.
MAX. NUMBER OF PIPES WITH OPENING IS THREE (3).
3. A) FORMING MATERIAL - (NOT SHOWN) - NOM. 1" THICK POLY
URETHANE BACKER ROD FRICTION FITTED INTO OPENING.
B) NOM. 1/2" FYRE-SHIELD THICKNESS INSTALLED WITHIN OPENING.


NOTE: FOR WALL APPLY FYRE-SHIELD TO BOTH SURFACES OF WALL.



CAJ 2221

2 HOUR FIRE RATED THROUGH
PENETRATION FIRESTOP FOR SINGLE
PLASTIC PIPE THROUGH
CONCRETE FLOORS OR WALLS
USING BLAZEMASTER CAULK & WALK

F-RATING = 2 HR.
T-RATING = 1-1/2 HR.

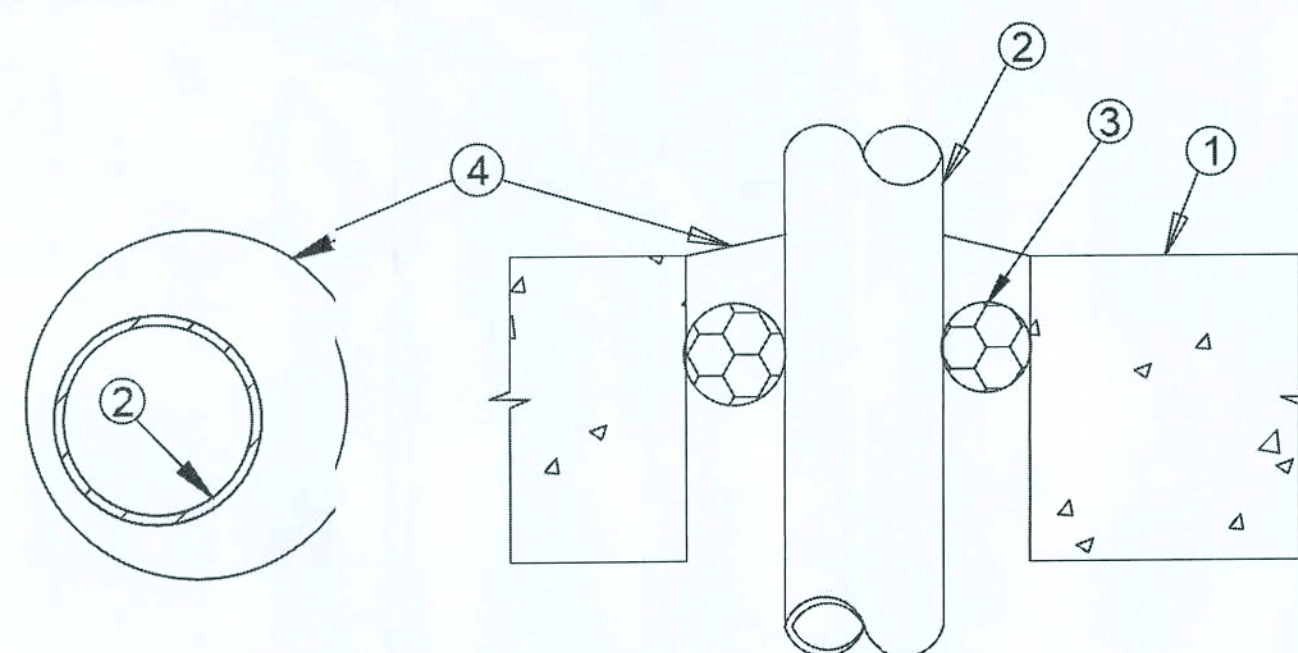


1. PRE-RATED CONCRETE FLOORS OR BLOCK WALLS = MIN. 4-1/2" THICKNESS
2. PLASTIC PIPE- A) NOM. 2" DIA. (OR SMALLER) SCH. 40 PVC PIPE.
B) NOM. 2 DIA. (OR SMALLER) CPVC PIPE
THE ANNULAR SPACE RANGE SHALL BE MIN MIN 1/4" TO MAX 3/8"
NOTE: DO NOT USE IN CLOSED (PROCESS OR SUPPLY) PIPING SYSTEMS.
3. FORMING MATERIAL - FOAM BACKER ROD FIRMLY PACKED INTO THE OPENING
AS A PERMAIENT FORM.
4. BLAZEMASTER CAULK & WALK - MIN 1/2" THICKNESS OF SEALANT APPLIED
WITHIN OPENING, FLUSH TOP SURFACE OF FLOOR OR BOTH SURFACES OF
WALL ASSEMBLY



WL2151

1 OR 2 HOUR FIRE RATED THROUGH
PENETRATION FIRESTOP FOR
PLASTIC PIPE THROUGH
GYPSUM WALLS USING
FYRE-CAN SLEEVE

F-RATING = 2 HR.
T-RATING = 1 HR.

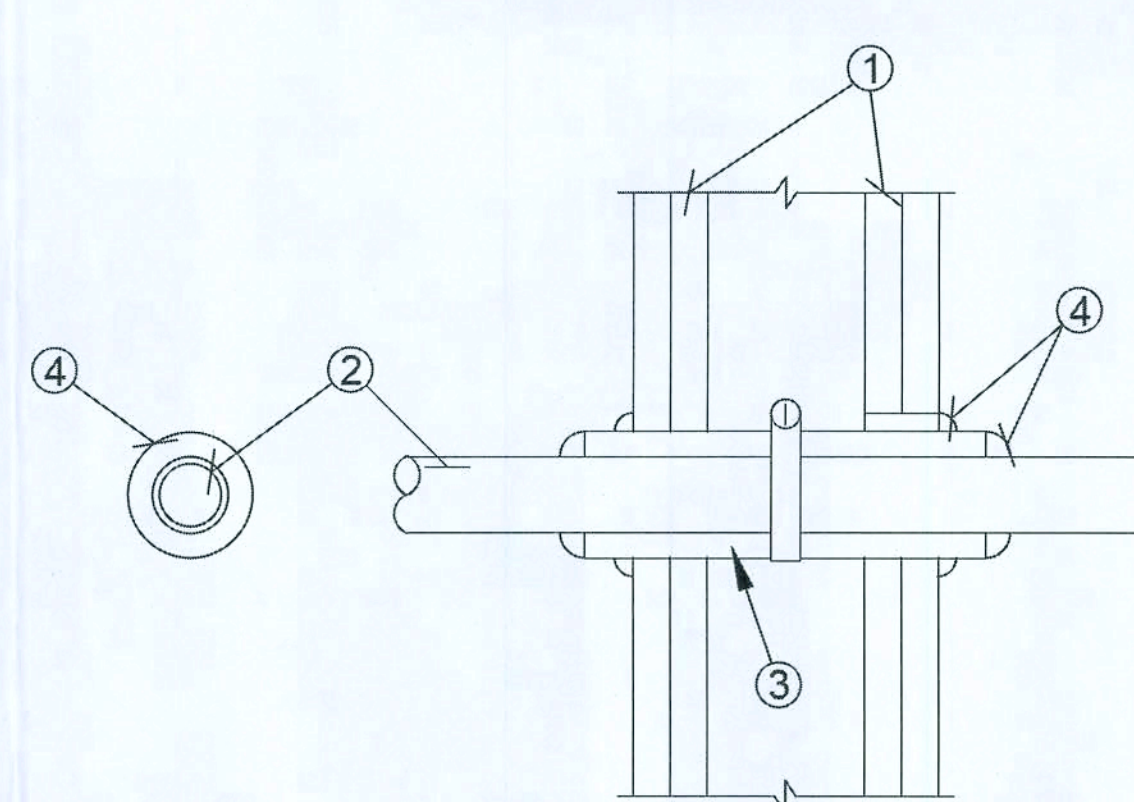

1. PRE-RATED GYPSUM WALLBOARD/STUD ASSEMBLY.
2. PLASTIC PIPE - 3" DIA. OR 2" DIA. SCH.40 PVC FOR USE
IN CLOSED OR VENTED PIPING SYSTEMS.
3. FYRE-CAN SLEEVE/INTUMESCENT DEVICE:

NOM. PIPE DIAM. (IN.)	DEVICE SIZE	DIAM. OF OPENING (IN.)	ANNULAR SPACE (IN.)
2	TS2	3-1/2	1/4 TO 7/8
3	TS3	4-3/4	1/2 TO 3/4

4. TREMSTOP WBM - MIN. 1/4" THICK SEALANT APPLIED AT
SLEEVE/PIPE AND SLEEVE/WALL INTERFACES.

Tremco

3735 Green Rd.
Beachwood, OH44122

DRAWING NOT TO SCALE

THE PRODUCTS USED IN THE ABOVE ASSEMBLY HAVE
BEEN TESTED IN ACCORDANCE WITH THE FOLLOWING:

- ASTM E814 (UL1479) STANDARD TEST METHOD
FOR THROUGH PENETRATION FIRESTOPPING.
- ASTM E119 (UL 263) STANDARD FOR FIRE TESTS
OF BUILDING CONSTRUCTION AND MATERIALS.

The above described assembly and
products have been tested and are
based on both past and anticipated
performance criteria. tremco shall
not be liable for any damages, direct
or consequential, resulting from use
of this material or design. tremco
shall only be responsible for replacing
material found to be defective.

REVISIONS


SMITH - SORENSON
LAKE CITY, FLORIDA 32055

PROJECT

DRAWING TYPE
FIRE ALARM
PLAN


CARIBBEAN FIRE & SECURITY, INC.
3856 S.W. 30th AVE.
HOLLYWOOD, FLORIDA 33312
(954)581-9393 FAX:(954)581-2896

CONTRACTOR

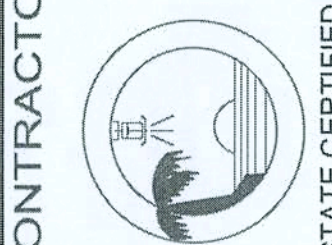

STATE CERTIFIED EF 20000969

Important: This material is the property of Caribbean Fire & Security, Inc. and is loaned for
review and evaluation purposes only. It is confidential as such, it is subject to recall at any
time and is not to be disclosed or transmitted to other parties nor copied in any form
without the prior written consent of Caribbean Fire & Security, Inc.

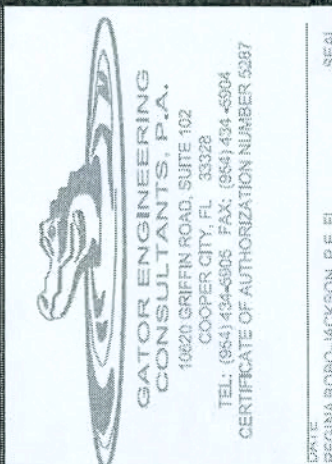

DWG #: 0928-81F-0703

REVISION: 0

DATE: 09/28/2020


SCALE: 1/8"=1'-0"

DRAWN BY F.O.

CHECKED BY S.P.

SHEET FA-3 OF 3

These drawings, as instruments of service, are the sole property of the architect, and may not be used, copied or reproduced in whole or in part for use on or incorporated within any other job without specific and individual authorization by the architect.

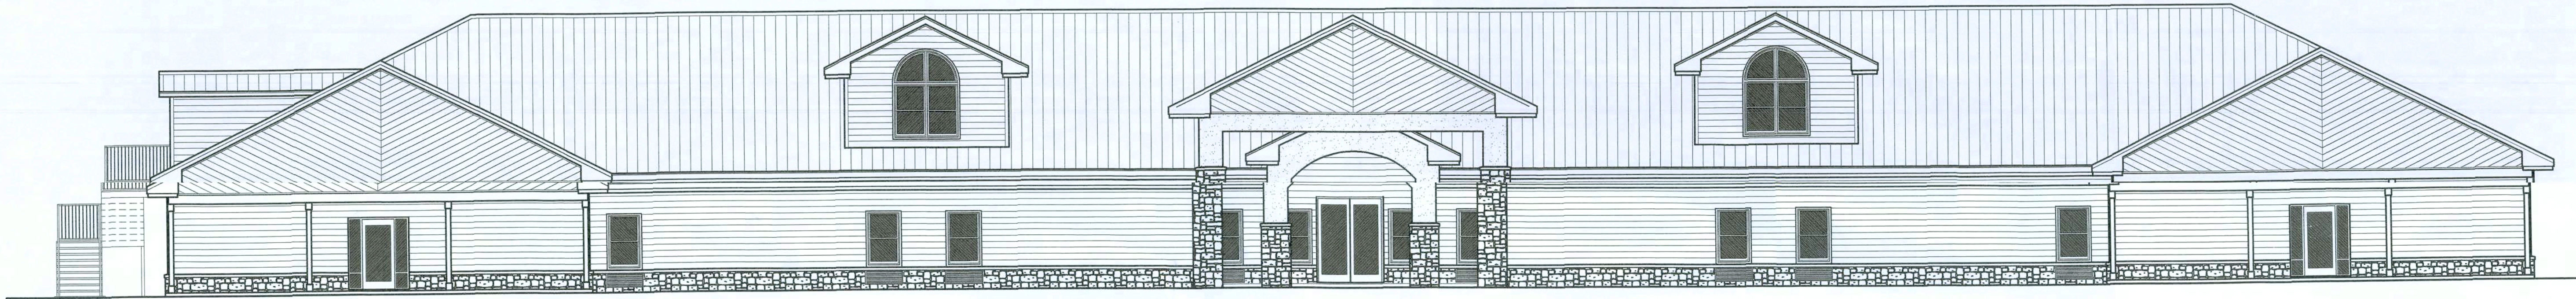

Assisted Living Facility for:
GRANDE CYPRESS
Lake City, Columbia County, Florida

Drawing Index

CS.1	COVER SHEET	S.1	STRUCTURAL INFORMATION
L&P.1	LIFE SAFETY PLAN	S.2	FOUNDATION PLAN
G.1	GENERAL INFORMATION	S.3	ROOF FRAMING PLAN
A.1	ELEVATIONS	S.4	LOFT FLOOR / ROOF FRAMING PLAN
A.2	ELEVATIONS, STAIRS DETAILS	S.5	TRUSS PROFILES / ROOF DETAILS
A.3	MAIN FLOOR PLAN	S.6	STRUCTURAL DETAILS
A.4	MAIN DIMENSION PLAN	FME.1	MAIN PLUMBING PLAN
A.5	MAIN FLOOR PLAN	FME.2	PLUMBING NOTES & DETAILS
A.6	MAIN DIMENSION PLAN	FME.3	MAIN H.V.A.C. PLAN
A.7	ENLARGED PLANS	FME.4	H.V.A.C. NOTES & DETAILS
A.8	WALL SECTIONS & DETAILS	FME.5	LOFT FME PLANS
A.9	MILLWORK DETAILS	FME.6	MAIN ELECTRICAL PLAN
A.10	WINDOW & STOREFRONT DETAILS	FME.7	ELECTRICAL NOTES, SYMBOLS, PANELS, CALCULATIONS & RISER
A.11	METAL ROOFING DETAILS		



APPROVED (Subject to Revisions)
Life Safety Services
Columbia County Fire Rescue
Florida State Fire Inspector # 136416
By: *[Signature]* Date: 10-9-2020

Digitally signed by N. P. GEISLER
DN: cn = N. P. GEISLER c = US
o = AR0007005, ou = ARCHITECT
Date: 2020.08.19 15:36:45-0500

REVISION:

Copyright 2020
N.P. Geisler, Architect

DRAWN:
NPG

ASSISTED LIVING FACILITY for
GRANDE CYPRESS
LAKE CITY, COLUMBIA COUNTY, FLORIDA
COVER SHEET

Celebrating
48 Years of Service
1972-2020
N.P. Geisler, Architect
AR0007005

NICHOLAS
GEISLER
ARCHITECT
N.C.A.A. Certified

DATE:
18 AUG 2020

CONTRACT:
2K2040

SHEET:
CS.1
1 OF 1

AR0007005

A.D.A. NOTES: ACCESSIBILITY

RESTROOM NOTES

WATERCLOSETS: SHALL COMPLY WITH SEC. 4.16 OF ADA
HEIGHT OF SEAT SHALL BE IN ACCORDANCE WITH SEC. 4.16.3 OF 2A
FLUSH CONTROLS SHALL BE IN ACCORDANCE WITH SEC. 4.16.5 OF ADA

GRAB BARS: SHALL COMPLY WITH SEC. 4.16.4 OF ADA




DISPENSERS: SHALL COMPLY WITH SEC. 4.16.6 OF ADA

LAVATORIES, SINKS & MIRRORS: SHALL COMPLY W/ SECTION 4.19 OF ADA
HEIGHTS SHALL COMPLY WITH SEC. 4.19.2.1 OF ADA
EXPOSED PIPES & SURFACES SHALL COMPLY W/ SECTION 4.19.4 OF ADA
FAUCETS SHALL COMPLY WITH SEC. 4.19.5 OF ADA
MIRRORS SHALL COMPLY WITH SEC. 4.19.6 OF ADA

OWNER SELECTED MATERIAL AND INSTALLATION OF FINISH FLOORING MATERIALS TO COMPLY WITH THE FOLLOWING:

SEC. 4.05 OF ADA
SEC. 4.03 OF ADA
APPLICABLE SECTIONS OF NFPA FIRE CODES
APPLICABLE SECTIONS OF NFPA 101-LATEST LIFE SAFETY CODE



FIXTURES, DEVICES AND RELATED HARDWARE NOT SPECIFICALLY DEFINED OR MENTIONED ELSEWHERE ARE TO BE OWNER SELECTED AND INSTALLED TO COMPLY WITH THE ABOVE APPLICABLE ADA SECTIONS.

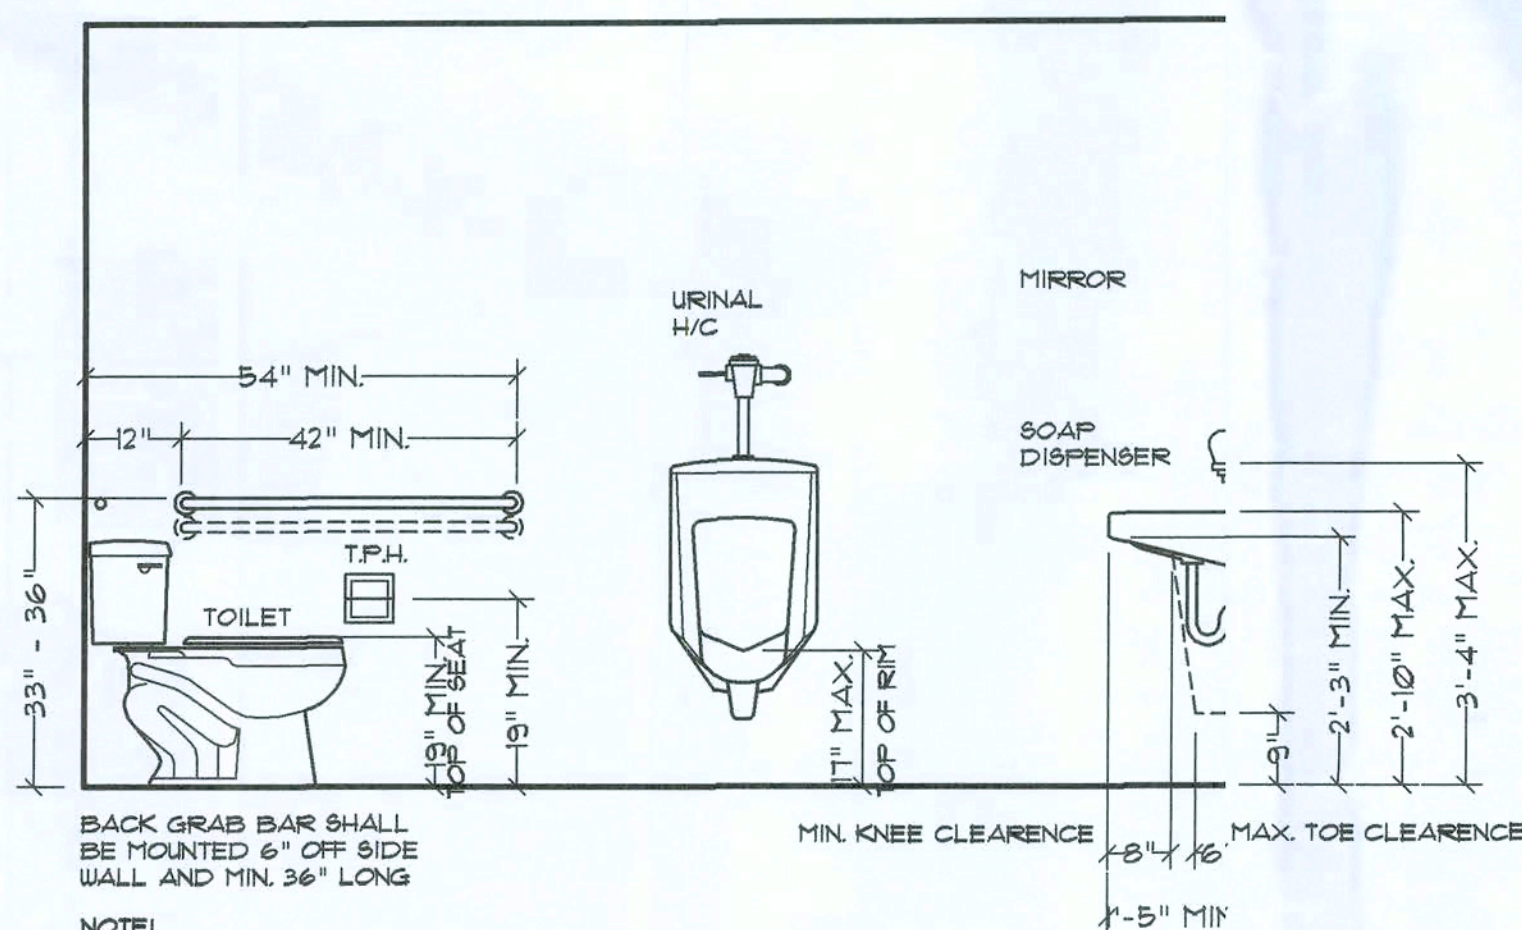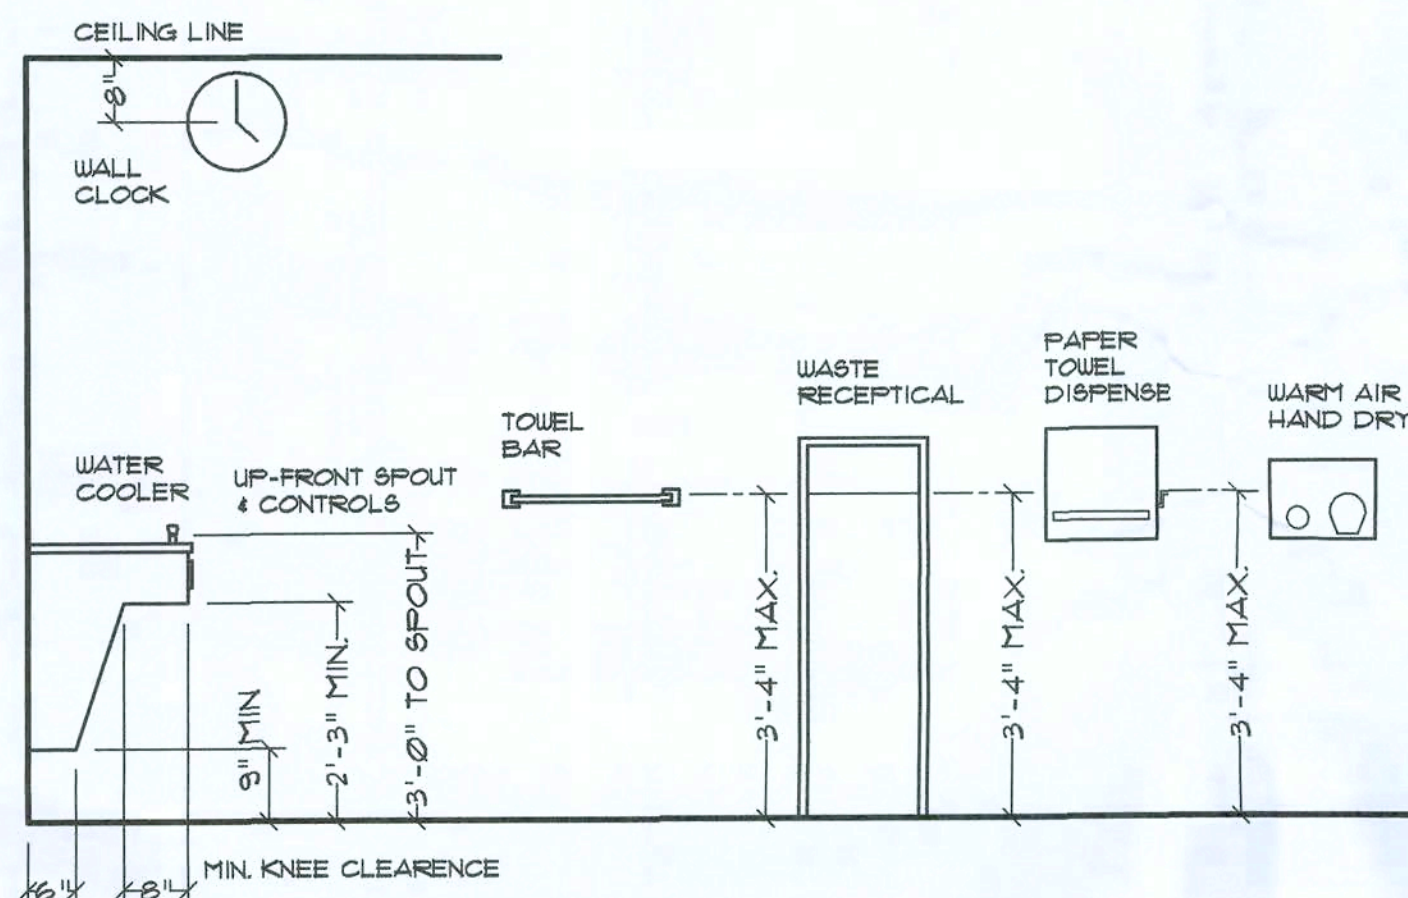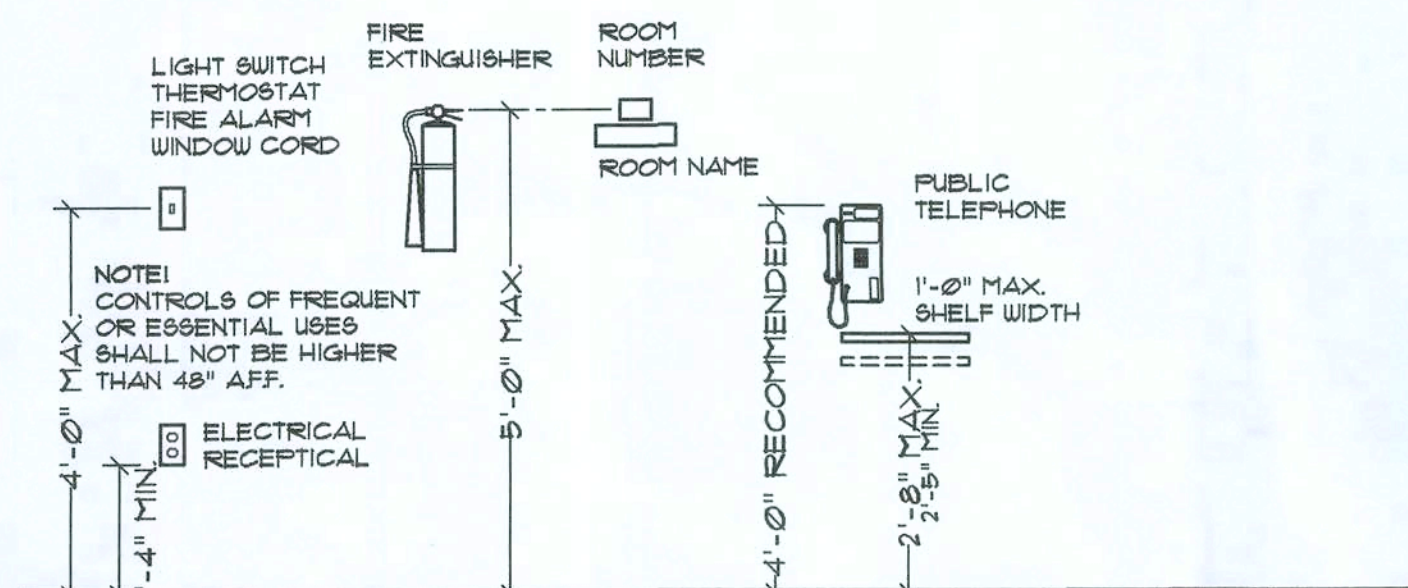

NOTE:
FLUSH VALVE SHALL BE ON WIDE
SIDE OF TOILET (LAV. SIDE WHERE
APPLICABLE) PER A.D.A. REQUIREMENTS

STANDARD MOUNTING PER A.D.A. REQUIREMENTS

SCALE: 1/2" = 1'-0"

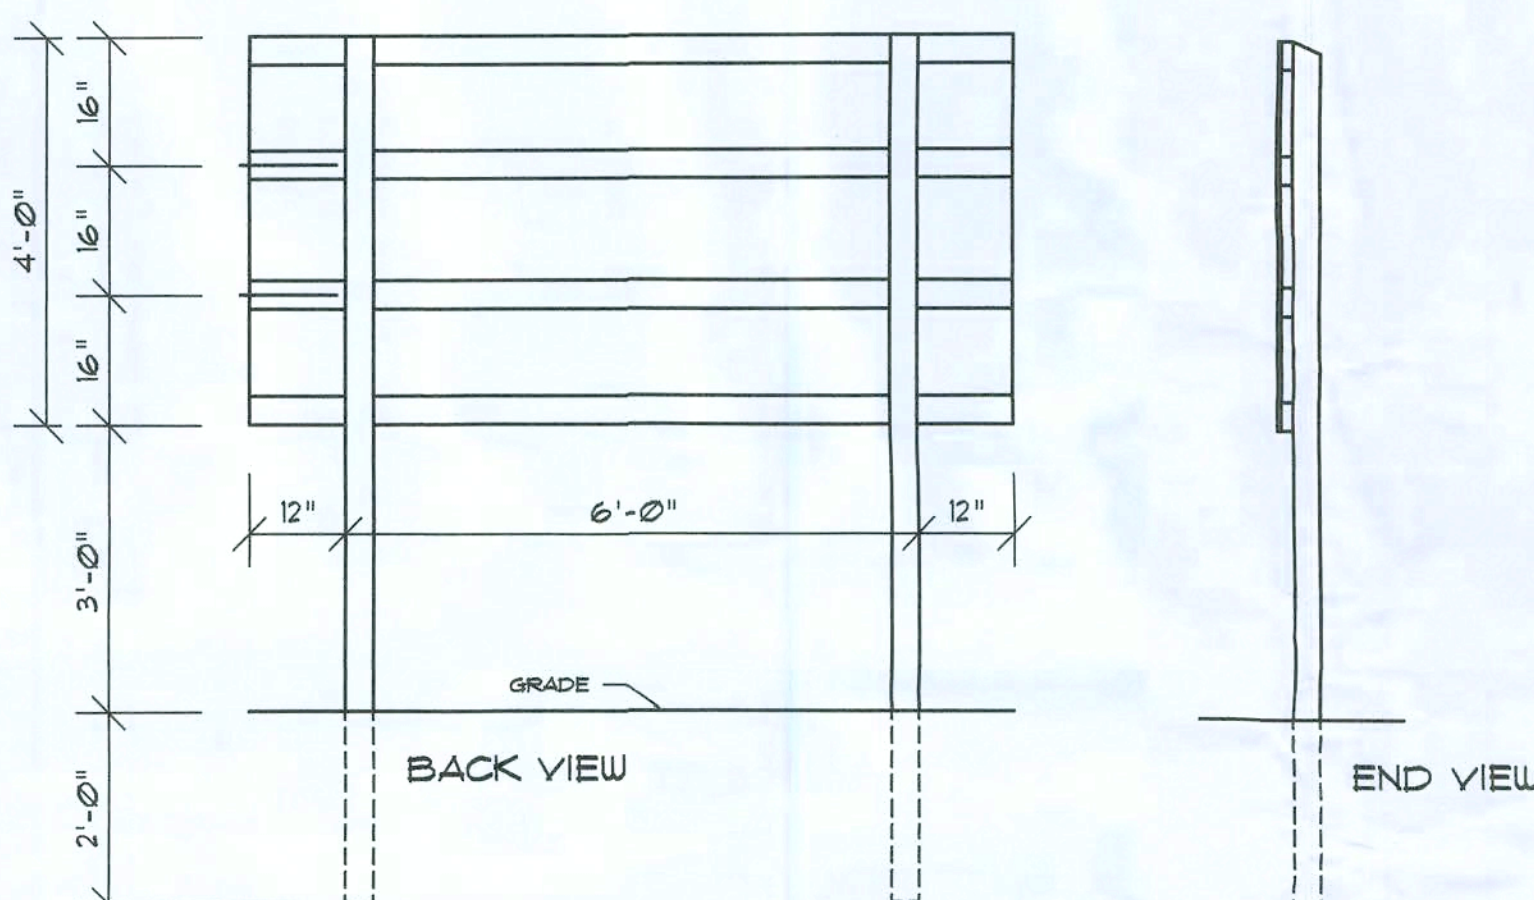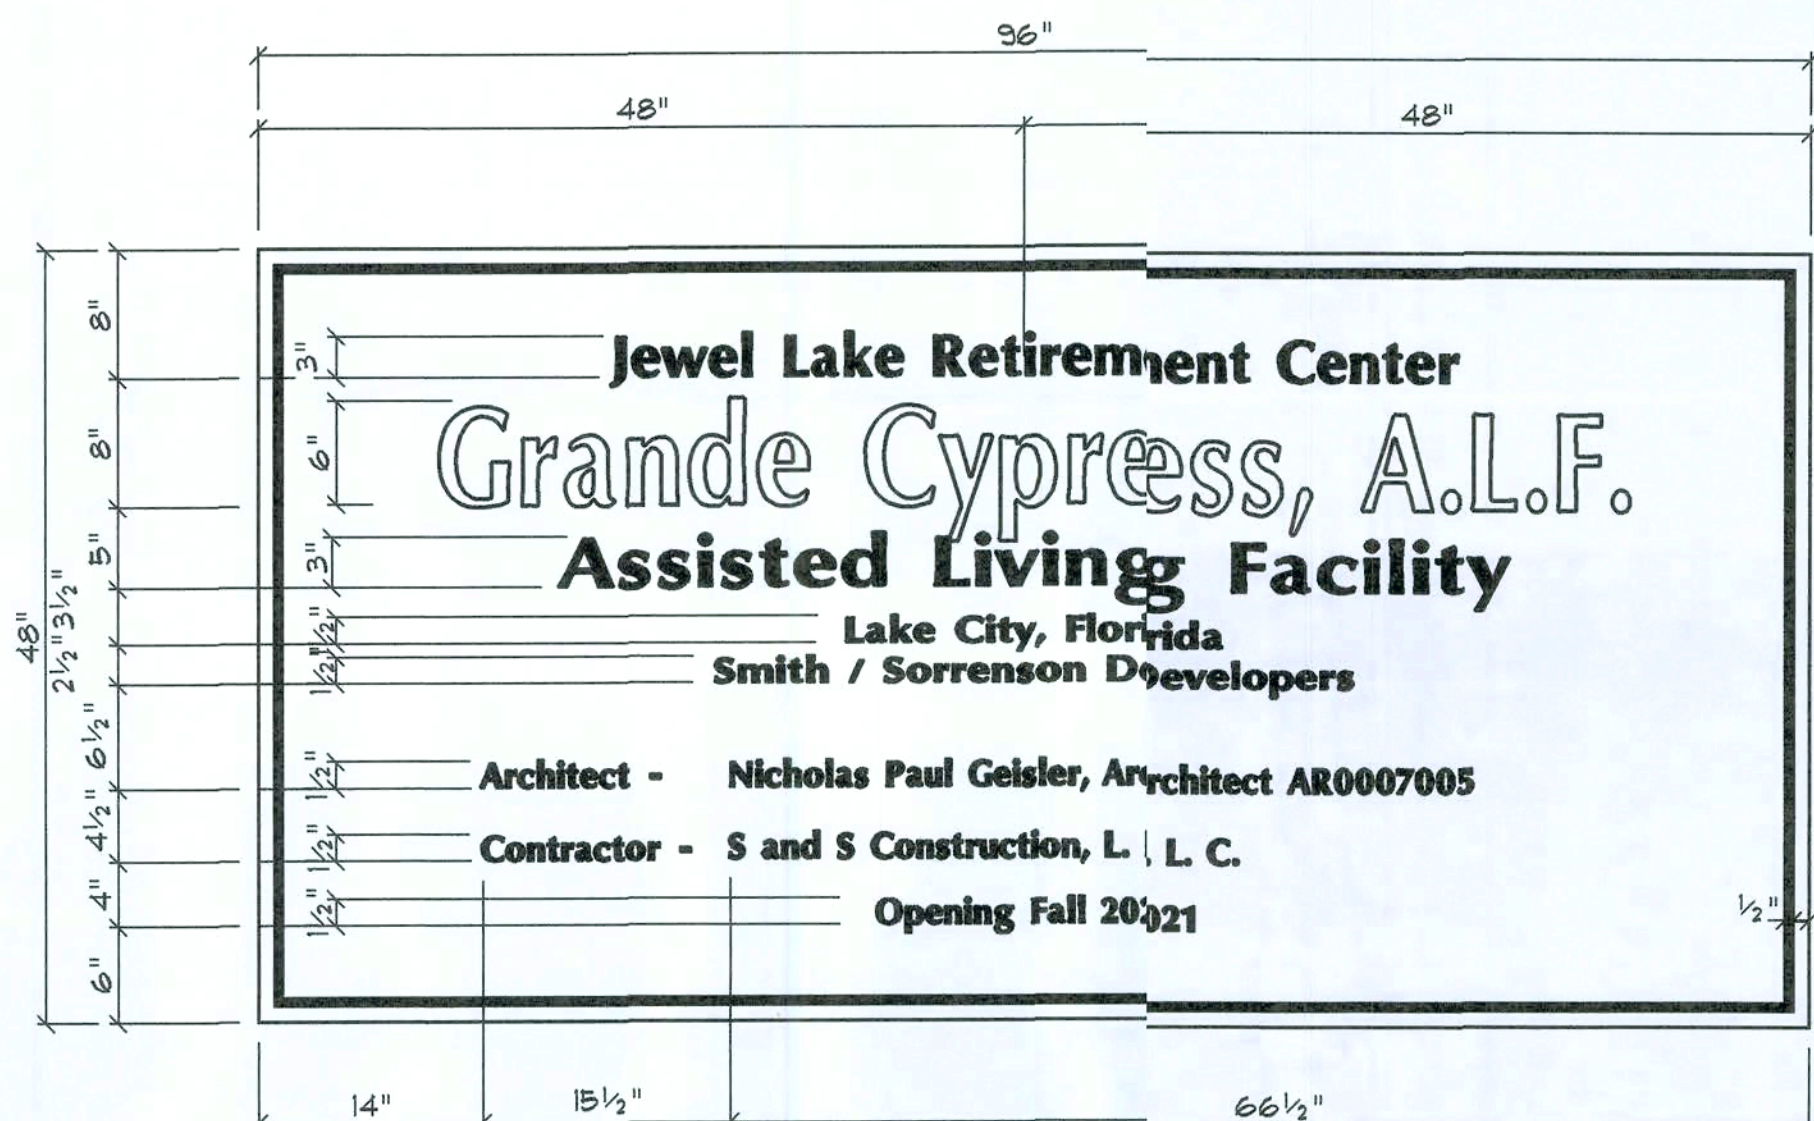

Construction Sign DETAILS

SCALE: FACE: 1" = 1'-0" / DETAILS: 1/2" = 1'-0"

SIGNAGE NOTES

- BACKING SHALL BE 48" X 96" X 1/2" ACX PLYWOOD, PRIMED AND PAINTED 2 COATS WHITE EXTERIOR ENAMEL.
- SUPPORTS SHALL BE 4 - P/T 2X4 AT 16" O.C., AS SHOWN.
- POSTS SHALL BE P/T 4X4, DIRECT BURIED, WITH THE TOP FACE CUT AT A 30° ANGLE AS SHOWN.
- ASSEMBLY SHALL BE WITH 8 - 1/4" X 6" CARRIAGE BOLTS W/ 1" WASHERS AND NUTS - 4 EACH POST.
- THIS BORDER SHALL BE A 1/2" WIDE BLACK STRIPE SET 1" IN FROM THE SIGN EDGE, ALL AROUND.
- TEXT SHALL BE BLACK FOR ALL LINES EXCEPT THE 2nd LINE, WHICH SHALL BE LIGHT BLUE WITH 1/8" BLACK PIPING.
- TEXT SPACING AND HEIGHT SHALL BE AS THE DETAIL.
- FONT STYLE SHALL BE OPTIMA BOLD.

GENERAL NOTES:

- THE CONTRACTOR SHALL INDEMNIFY THE OWNER AGAINST ALL CLAIMS, WHETHER FROM PERSONAL INJURY OR PROPERTY DAMAGE, ARISING FROM EVENTS ASSOCIATED WITH THE WORK PERFORMED UNDER THE CONTRACT FOR THIS PROJECT.
- THE CONTRACTOR AND/OR SUB-CONTRACTORS SHALL WARRANT ALL WORK FOR A PERIOD OF ONE YEAR FOLLOWING THE DATE OF FINAL COMPLETION AND ACCEPTANCE BY THE OWNER. DEFECTS IN MATERIALS, EQUIPMENT, COMPONENTS AND WORKMANSHIP SHALL BE CORRECTED AT NO FURTHER COST TO THE OWNER DURING THE ONE YEAR WARRANTY PERIOD.
- AT THE OWNER'S OPTION, A WARRANTY INSPECTION SHALL BE PERFORMED DURING THE ELEVENTH MONTH FOLLOWING THE COMMENCEMENT OF THE WARRANTY PERIOD, FOR THE PURPOSE OF DETERMINING ANY WARRANTY WORK THAT MAY BE REQUIRED. THE CONTRACTOR SHALL BE PRESENT DURING THIS INSPECTION IF REQUESTED BY THE OWNER.
- THE CONTRACTOR SHALL PAY FOR ALL PERMITS, LICENSES, TESTS AND THE LIKE THAT MAY BE REQUIRED BY THE VARIOUS AUTHORITIES HAVING JURISDICTION OVER THIS PROJECT BE THEY CITY, COUNTY, STATE OR FEDERAL.
- THE OWNER SHALL FILE A "NOTICE OF COMMENCEMENT" PRIOR TO THE BEGINNING OF THE PROJECT AND THE CONTRACTOR(S) SHALL FILE "NOTICE TO OWNER" AND PROVIDE "RELEASE OF LIEN" FOR ALL PAYMENT REQUESTS PRIOR TO DISBURSEMENT OF ANY FUNDS.
- ANY AND ALL DISPUTES ARISING FROM EVENTS ASSOCIATED WITH THE CONSTRUCTION OF THIS PROJECT BETWEEN THE OWNER, CONTRACTOR(S) AND SUPPLIERS SHALL BE RESOLVED THROUGH BINDING ARBITRATION.
- ALL WORK SHALL BE IN ACCORDANCE W/ APPLICABLE CODES AND LOCAL REGULATIONS, INCLUDING APPLICABLE ENERGY CODES. ALL COMPONENTS OF THE BUILDING SHALL MEET WITH THE MINIMUM ENERGY REQUIREMENTS OF THE BUILDING CODE. ANY DISCREPANCIES SHALL BE REPORTED TO THE ARCHITECT IN WRITING PRIOR TO THE COMMENCEMENT OF THE WORK.
- ALL INSULATION SHALL BE LEFT EXPOSED AND ALL CABLES LEFT INTACT ON THE WINDOWS AND DOORS UNTIL INSPECTED BY THE BUILDING OFFICIAL.
- ALL WOOD IN CONTACT WITH CONCRETE OR MASONRY SHALL BE PRESURE TREATED.
- INTERIOR BEARING WALLS SHALL BE CONSTRUCTED IN COMPLIANCE WITH "UL Design U333", BATT INSULATION SHALL BE INCLUDED WHERE UNCONDITIONED AREA IS BEING SEPARATED FROM HEATED / COOLED AREA.
- INTERIOR STUD WALLS SEPARATING LIVING AREA FROM GARAGE AREAS SHALL BE CONSTRUCTED IN COMPLIANCE WITH "UL Design U333", INCLUDING R-11 BATT INSULATION.
- CEILING OVER ATTACHED GARAGES OR GARAGES W/ LIVING AREA ABOVE SHALL BE 5/8" FIRECODE "C" GIBS ON 1X3 WOOD FURRING AT 16" O.C., ATTACHED W/ 1 1/4" BUGLEHEAD SCREWS @ 6" O.C. ALONG EACH POINT OF BEARING.

STANDARD ABBREVIATIONS

@	AT	GALV.	GALVANIZED
#	NUMBER OF POUND(S)	HORZ.	HORIZONTAL
=	EQUALS	INS.	INSULATION
Ø	DIAMETER	INT.	INTERIOR
W/	WITH	LAV.	LAVATORY
W/O	WITHOUT	LVL.	LAMINATED VENEER LUMBER
CL	CENTERLINE	MAX.	MAXIMUM
&	AND	MIN.	MINIMUM
+ or -	PLUS OR MINUS	MISC.	MISCELLANEOUS
1'	ONE FOOT	M.O.	MASONRY OPENING
1"	ONE INCH	No. or N°.	NUMBER
1/4" or 1/8"	ONE QUARTER INCH	O.C.	ON CENTER
8d	8 PENNY	OH	OVERHEAD
BM	BEAM	OH	OVERHEAD DOOR
B.O.	BY OTHERS	PLYD.	PLYWOOD
BOT.	BOTTOM	P/T	PRESSURE TREATED
CLG.	CEILING	REINF.	REINFORCING (ED)
CO	CLEANOUT	REQD	REQUIRED
CONC.	CONCRETE	RM.	ROOM
COTG	CLEANOUT TO GRADE	R.O.	ROUGH OPENING
DBL.	DOUBLE	SF	SQUARE FEET
DM.	DIMENSION	SLDG	SLIDING GLASS DOOR
DN.	DOWN	SHT.	SHEET
ELEV.	ELEVATION	SRH	SUWANEE RIVER LOG HOMES
EXT.	EXTERIOR	TYP.	TYPICAL
F	FRENCH (DOORS)	VERT.	VERTICAL
FDN.	FOUNDATION	WC	WATERCLOSET (TOILET)

PROJECT INFORMATION / NOTES:

DESIGN VALUES/LOADS & CODES

WIND DESIGN SPEED: 130 MPH, UNLESS NOTED OTHERWISE

SOIL DESIGN STATEMENT:
FOOTING DESIGN IS BASED UPON 1200PSF SOIL BEARING PRESSURE PROVIDED BY CLEAN SAND GRAVEL OR STONE. OTHER SOIL CONDITIONS IS: CLAY, HIGH LEVEL OF ORGANICS OR OTHER UNDESIRABLE SOILS SHALL REQUIRE FOUNDATION MODIFICATIONS.

LIVE LOADS: 1st FLOOR: 40PSF, 2nd FLOOR: 40PSF, ROOF: AS DETERMINED BY SHAPE FACTORS APPLIED TO THE WIND FORCE GENERATED BY THE DESIGN WIND SPEED.

BUILDING CODE: 2011 FLORIDA BUILDING CODE, 6th EDITION

ELECTRICAL CODE: NATIONAL ELECTRICAL CODE - LATEST
LIFE SAFETY: NFPA-101 - LATEST

CONSTRUCTION DOCUMENTS

THE CUSTOMER IS RESPONSIBLE FOR DELIVERING THE REQUIRED SETS OF CONSTRUCTION DOCUMENTS TO THE PERMIT ISSUING AUTHORITIES, FOR THE ISSUANCE OF CONSTRUCTION PERMITS. THE CONTRACTOR SHALL REVIEW THE CONSTRUCTION DOCUMENTS AND VERIFY ALL DIMENSIONS. ANY DISCREPANCIES SHALL BE REPORTED TO THE ARCHITECT PRIOR TO THE COMMENCEMENT OF ANY WORK OR FABRICATION OF ANY MATERIALS.

DO NOT SCALE OFF THESE PLANS

AMPLE DIMENSIONS ARE SHOWN ON THE PLANS TO LOCATE ALL ITEMS. SIMPLE ARITHMETIC MAY BE USED TO DETERMINE THE LOCATIONS OF THOSE ITEMS NOT DIMENSIONED.

CHANGES TO FINAL PLAN SETS

PLEASE DO NOT MAKE ANY STRUCTURAL CHANGES TO THESE PLANS WITHOUT CONSULTING WITH THE ARCHITECT. THE OWNER SHALL ASSUME ANY AND ALL LIABILITY FOR STRUCTURAL DAMAGE RESULTING FROM CHANGES MADE TO THE PLANS OR BY SUBSTITUTION OF MATERIALS DIFFERENT FROM SPECIFICATION ON THE PLANS.

AS - BUILT DRAWING REQUIREMENTS:

- ELECTRICAL "AS-BUILT" DRAWINGS**
ELECTRICAL CONTR SHALL PREPARE "AS-BUILT" SHOP DUGS INDICATING ALL ELECTRICAL WORK, INCLUDING ANY CHANGES TO THE ELEC. PLAN, ADDS TO THE ELEC. PLAN, RISER DIAGRAM, AS-BUILT PANEL SCHEDULE W/ ALL CKTS IDENTIFIED W/ CKT N°. DESCRIPTION & BRKR. SERVICE ENT. & ALL UNDERGROUND WIRE LOCATIONS/ROUTING/DEPTH. RISER DIA. SHALL INCLUDE WIRE SIZES/TYPES & EQUIPMENT TYPE W/ RATINGS & LOADS.
CONTRACTOR SHALL PROVIDE 1 COPY OF AS-BUILT DUGS TO OWNER & 1 COPY TO THE PERMIT ISSUING AUTHORITY.
- HVAC "AS-BUILT" DRAWINGS**
HVAC CONTRACTOR SHALL PREPARE "AS-BUILT" SHOP DUGS INDICATING ALL HVAC WORK, INCLUDING ALL DUCTWORK LOC. SIZES, LINES, EQUIPMENT SCH. & BALANCING REPORT - CONTR SHALL PROVIDE 1 COPY OF AS-BLT. DUGS TO OWNER & 1 COPY TO THE PERMIT ISSUING AUTHORITY.
- PLUMBING "AS-BUILT" DRAWINGS**
PLUMBING CONTRACTOR SHALL PREPARE "AS-BUILT" SHOP DUGS INDICATING ALL PLUMBING WORK, INCLUDING ALL PLUMBING LINE LOCATIONS AND RISER DIAGRAM - CONTR SHALL PROVIDE 1 COPY OF AS-BUILT DUGS TO OWNER AND 1 COPY TO THE PERMIT ISSUING AUTHORITY.

SYMBOLS

THESE SYMBOLS ARE MOST OFTEN ENCOUNTERED IN THE FOLLOWING DRAWINGS: ELEVATIONS, DIMENSION PLANS, SECTIONS & STRUCTURAL PLANS

	TYPE OF ELEVATION MARK USED TO INDICATE A PREFERRED TARGET ELEVATION - TRUE MEASUREMENT.
	TYPE OF ELEVATION MARK USED TO INDICATE THE TOP OF A LOG WALL STACK - NOMINAL ONLY.
	TYPE OF DETAIL MARK USED TO INDICATE A SECTION OR DETAIL ASSOCIATED WITH A PLAN VIEW
	TYPE OF DETAIL MARK USED TO INDICATE A SECTION OR DETAIL ASSOCIATED WITH A PLAN VIEW
	TYPE OF SECTION MARK USED TO INDICATE A VIEW TAKEN IN THE DIRECTION OF THE ARROW
	INDICATES FOOTING TYPE "A", DESCRIBED IN THE FOOTING SCHEDULE
	INDICATES POST/COLUMN TYPE "1", DESCRIBED IN THE COLUMN SCHEDULE
	INDICATES POST/COLUMN TYPE "1", LOCATED BELOW CURRENT LEVEL
	INDICATES POST/COLUMN TYPE "1", LOCATED ABOVE CURRENT LEVEL
	INDICATES POST/COLUMN TYPE "1", LOCATED OVER TYPE "1" POST/COLUMN

REVISION:
22 SEP 2020

Copyright 2020
N.P. Gesler, Architect

DRAWN:
NPG

BUILDING CODE: 2011 FLORIDA BUILDING CODE, 6th EDITION

ELECTRICAL CODE: NATIONAL ELECTRICAL CODE - LATEST
LIFE SAFETY: NFPA-101 - LATEST

CONSTRUCTION DOCUMENTS

THE CUSTOMER IS RESPONSIBLE FOR DELIVERING THE REQUIRED SETS OF CONSTRUCTION DOCUMENTS TO THE PERMIT ISSUING AUTHORITIES, FOR THE ISSUANCE OF CONSTRUCTION PERMITS. THE CONTRACTOR SHALL REVIEW THE CONSTRUCTION DOCUMENTS AND VERIFY ALL DIMENSIONS. ANY DISCREPANCIES SHALL BE REPORTED TO THE ARCHITECT PRIOR TO THE COMMENCEMENT OF ANY WORK OR FABRICATION OF ANY MATERIALS.

DO NOT SCALE OFF THESE PLANS


AMPLE DIMENSIONS ARE SHOWN ON THE PLANS TO LOCATE ALL ITEMS. SIMPLE ARITHMETIC MAY BE USED TO DETERMINE THE LOCATIONS OF THOSE ITEMS NOT DIMENSIONED.

CHANGES TO FINAL PLAN SETS

PLEASE DO NOT MAKE ANY STRUCTURAL CHANGES TO THESE PLANS WITHOUT CONSULTING WITH THE ARCHITECT. THE OWNER SHALL ASSUME ANY AND ALL LIABILITY FOR STRUCTURAL DAMAGE RESULTING FROM CHANGES MADE TO THE PLANS OR BY SUBSTITUTION OF MATERIALS DIFFERENT FROM SPECIFICATION ON THE PLANS.

AS - BUILT DRAWING REQUIREMENTS:

- ELECTRICAL "AS-BUILT" DRAWINGS**
ELECTRICAL CONTR SHALL PREPARE "AS-BUILT" SHOP DUGS INDICATING ALL ELECTRICAL WORK, INCLUDING ANY CHANGES TO THE ELEC. PLAN, ADDS TO THE ELEC. PLAN, RISER DIAGRAM, AS-BUILT PANEL SCHEDULE W/ ALL CKTS IDENTIFIED W/ CKT N°. DESCRIPTION & BRKR. SERVICE ENT. & ALL UNDERGROUND WIRE LOCATIONS/ROUTING/DEPTH. RISER DIA. SHALL INCLUDE WIRE SIZES/TYPES & EQUIPMENT TYPE W/ RATINGS & LOADS.
CONTRACTOR SHALL PROVIDE 1 COPY OF AS-BUILT DUGS TO OWNER & 1 COPY TO THE PERMIT ISSUING AUTHORITY.
- HVAC "AS-BUILT" DRAWINGS**
HVAC CONTRACTOR SHALL PREPARE "AS-BUILT" SHOP DUGS INDICATING ALL HVAC WORK, INCLUDING ALL DUCTWORK LOC. SIZES, LINES, EQUIPMENT SCH. & BALANCING REPORT - CONTR SHALL PROVIDE 1 COPY OF AS-BLT. DUGS TO OWNER & 1 COPY TO THE PERMIT ISSUING AUTHORITY.
- PLUMBING "AS-BUILT" DRAWINGS**
PLUMBING CONTRACTOR SHALL PREPARE "AS-BUILT" SHOP DUGS INDICATING ALL PLUMBING WORK, INCLUDING ALL PLUMBING LINE LOCATIONS AND RISER DIAGRAM - CONTR SHALL PROVIDE 1 COPY OF AS-BUILT DUGS TO OWNER AND 1 COPY TO THE PERMIT ISSUING AUTHORITY.

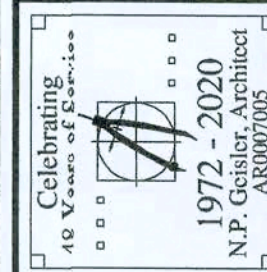

1755 NW Brown Rd.
Lake City, FL 32055
3516-3305-4305

NICHOLAS PAUL GESLER
ARCHITECT
REGISTERED

DATE:

16 AUG 2020

COMM:

K2040

SHEET:


G.1

1 OF 1

AR0007005

Digitally signed by N.P. GESLER
DN: cn = N.P. GESLER, c = US
Date: 2020.09.09 15:57:38 -0500

These drawings, as instruments of service, are the sole property of the architect, and may not be used, copied or reproduced in whole or in part for use on or incorporated within any other job without specific and individual authorization by the architect.

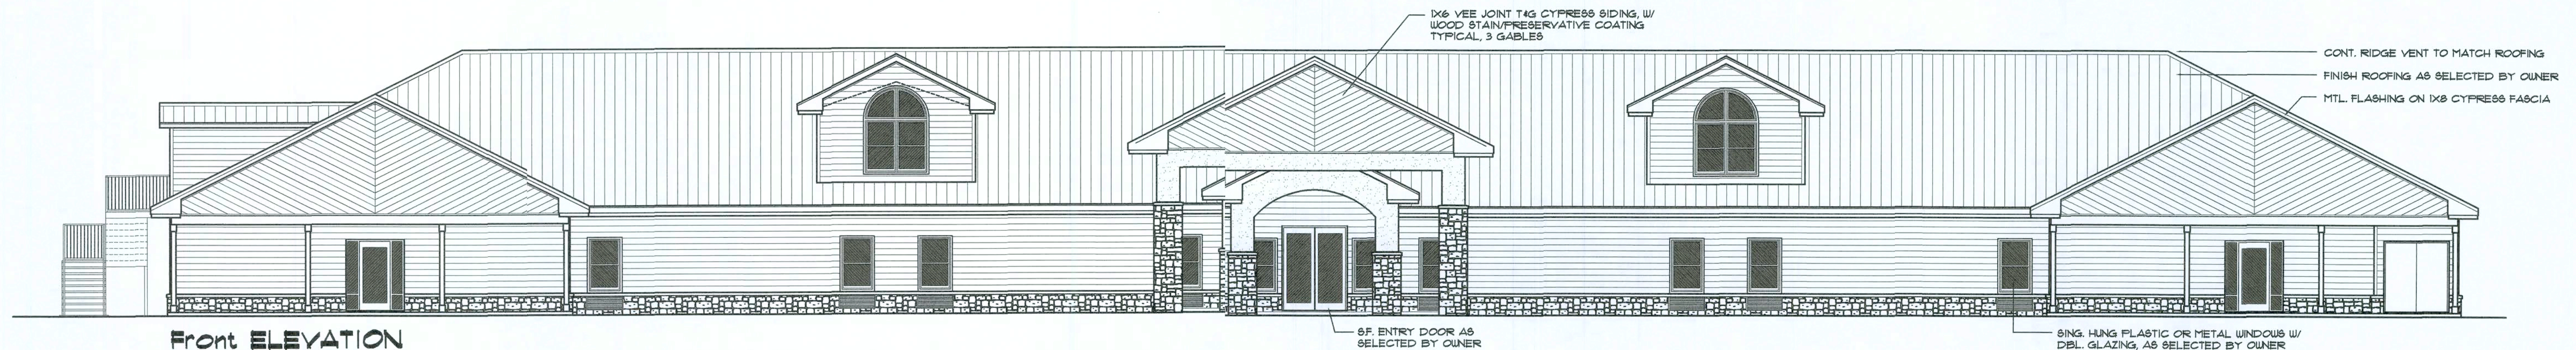


Front ELEVATION
SCALE: 1/8" = 1'-0"




Rear ELEVATION
SCALE: 1/8" = 1'-0"

HARDIEBOARD SIDING - AS SELECTED BY THE OWNER
CULTURED STONE VENEER - COLOR AND PATTERN
AS SELECTED BY THE OWNER W/ STONE WALL CAP

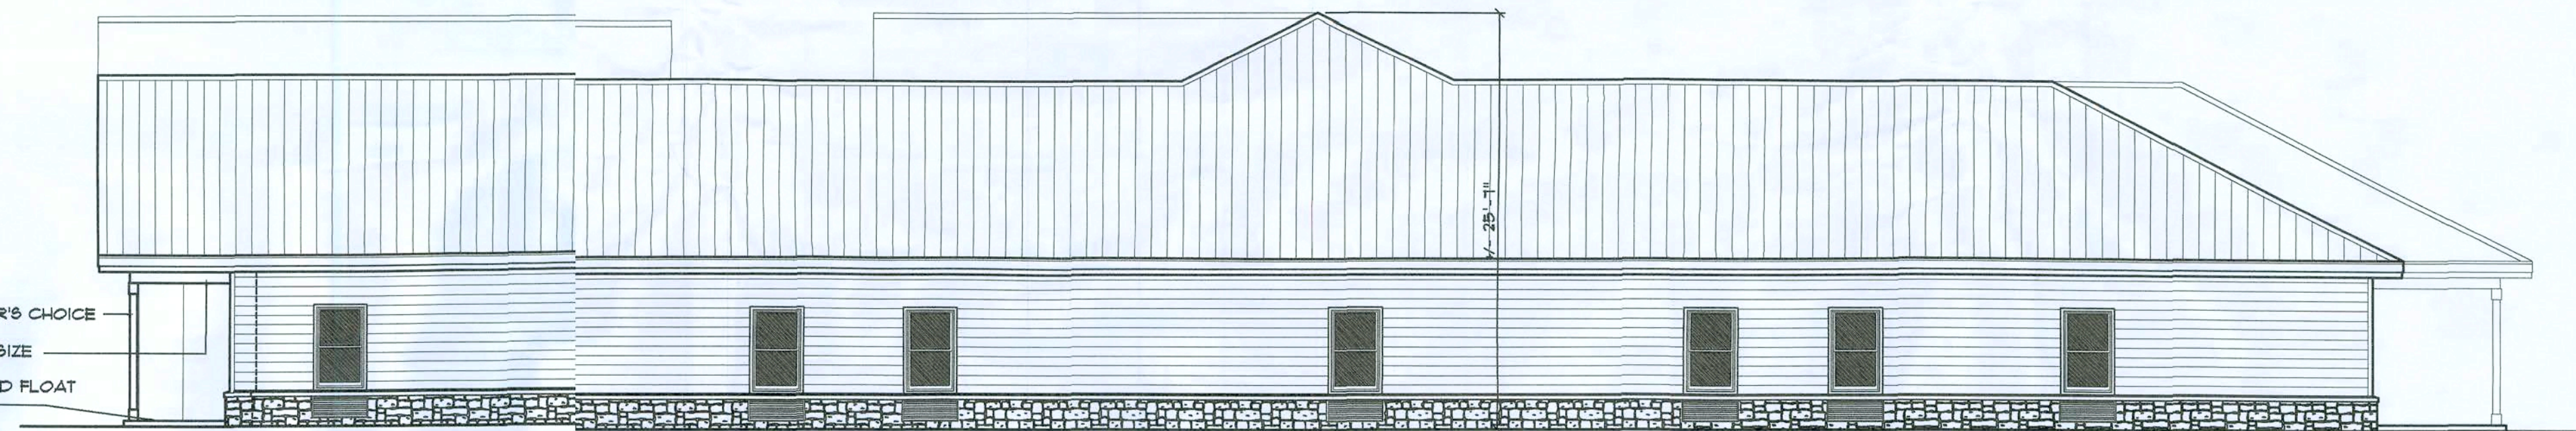

Right ELEVATION
SCALE: 1/8" = 1'-0"

PORCH POSTS, STYLE PER OWNER'S CHOICE
PORCH BEAM - SEE PLANS FOR SIZE
CONCRETE PORCH DECK, W/ WOOD FLOAT
FINISH & TOOLED EDGES

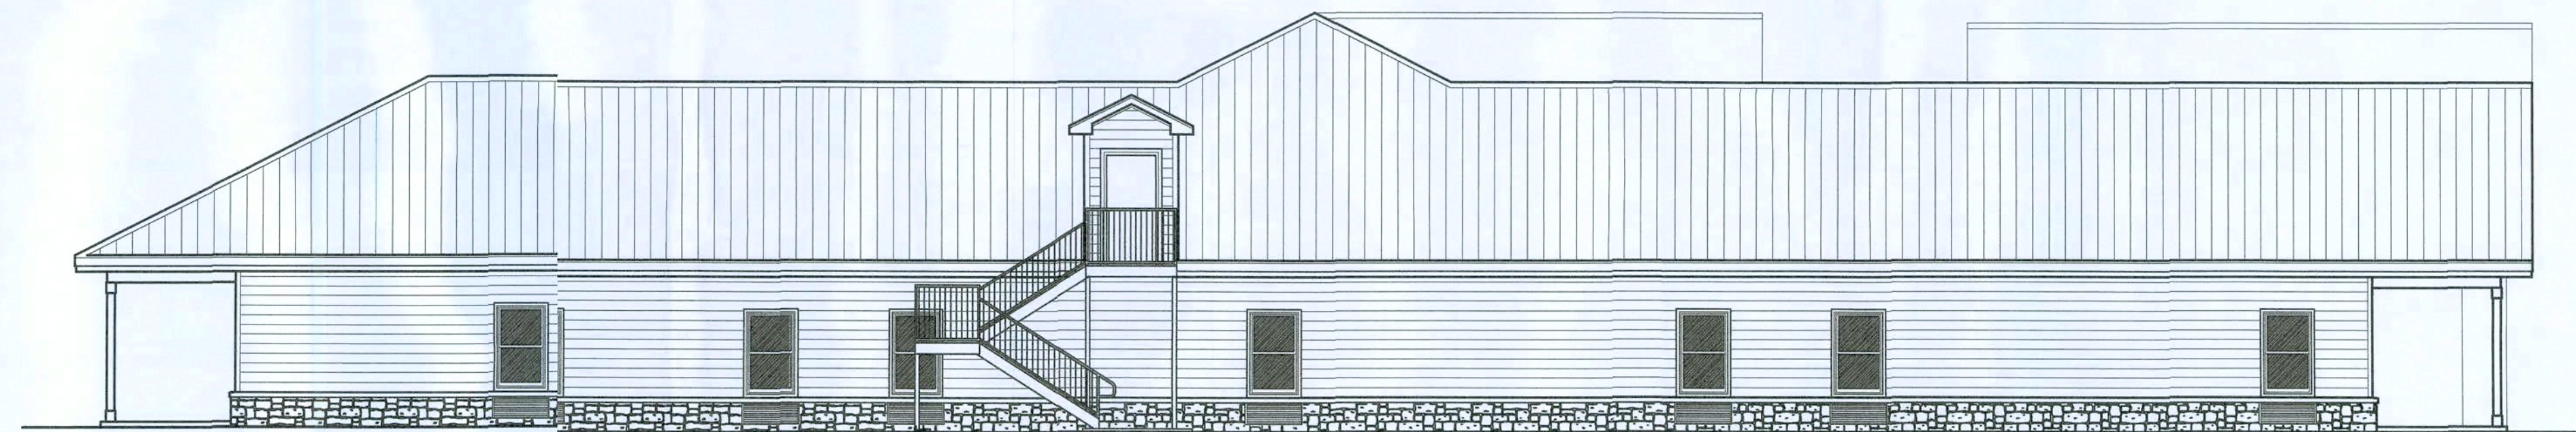

Left ELEVATION
SCALE: 1/8" = 1'-0"

Digitally signed by N.P. GESLER
DN: cn = N.P. GESLER c = US
o = ARCHITECT
ou = ARCHITECT
email = N.P.GESLER@GMAIL.COM
Date: 2020.08.09 16:03:07

REVISION:
22 SEP 2020

Copyright, 2020 ©
N.P. Gesler, Architect

DRAWN:
mg

ASSISTED LIVING FACILITY FOR
SMITH - SORENSEN
LAKE CITY, COLUMBIA COUNTY, FLORIDA
PROPOSED FLOOR PLAN


4th Year of Service
1972 - 2020
N.P. Gesler, Architect
ARCHITECT
A00000000

**NICHOLAS
GESLER
ARCHITECT**
N.C.A.R.B. Certified
1758 NW Broward Ave.
Suite 200
Fort Lauderdale, FL 33305
360-363-4355


DATE:
9 AUG 2020
COMB:
2K2040

SHEET:
A.1
1 OF 11


AF0007005

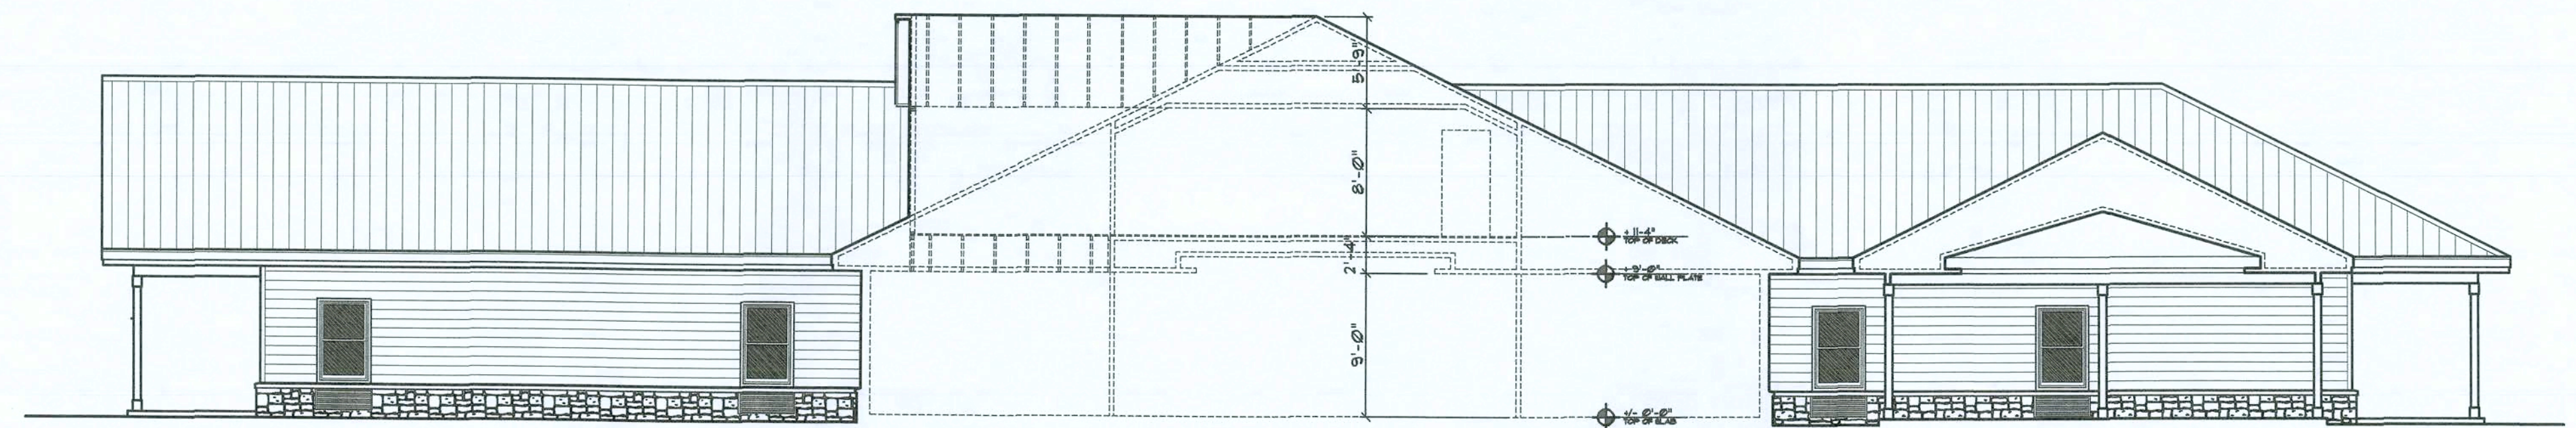

Courtyard ELEVATION

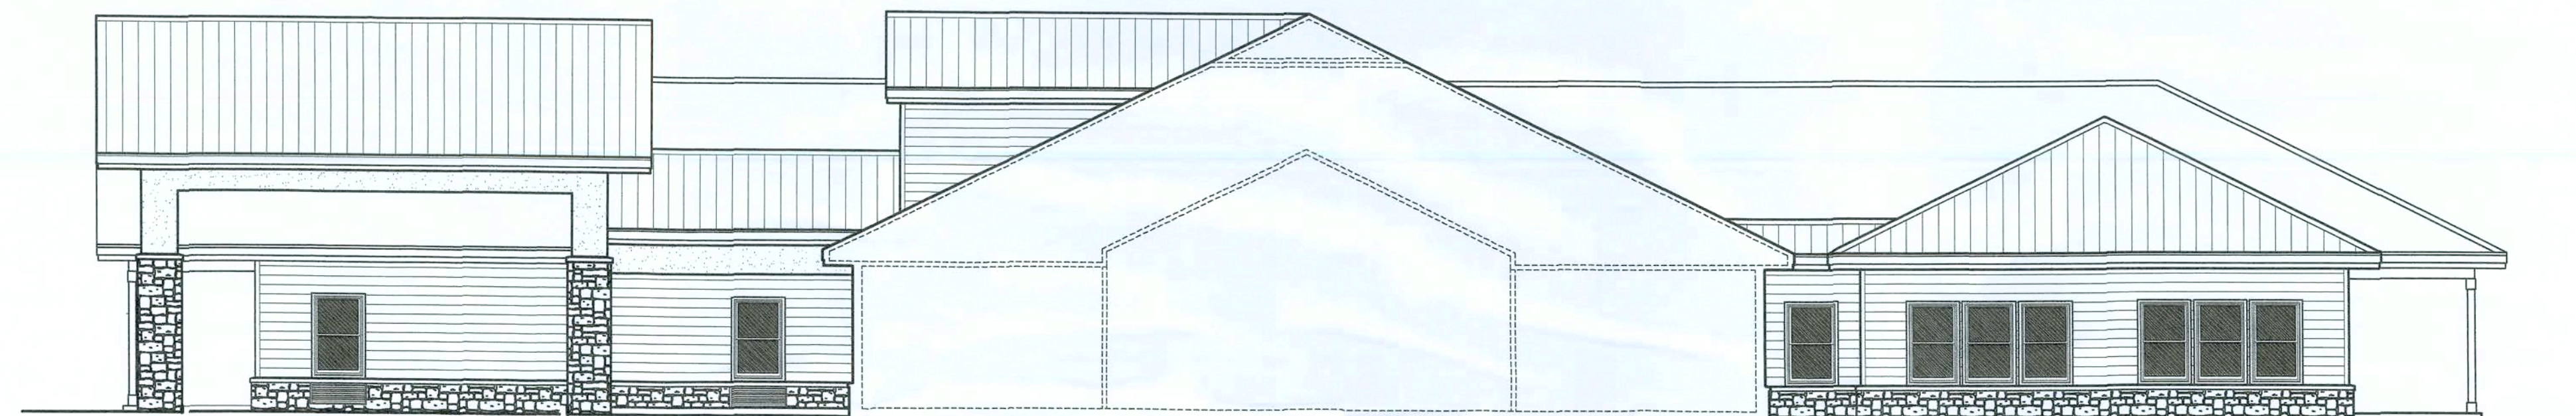


Courtyard ELEVATION

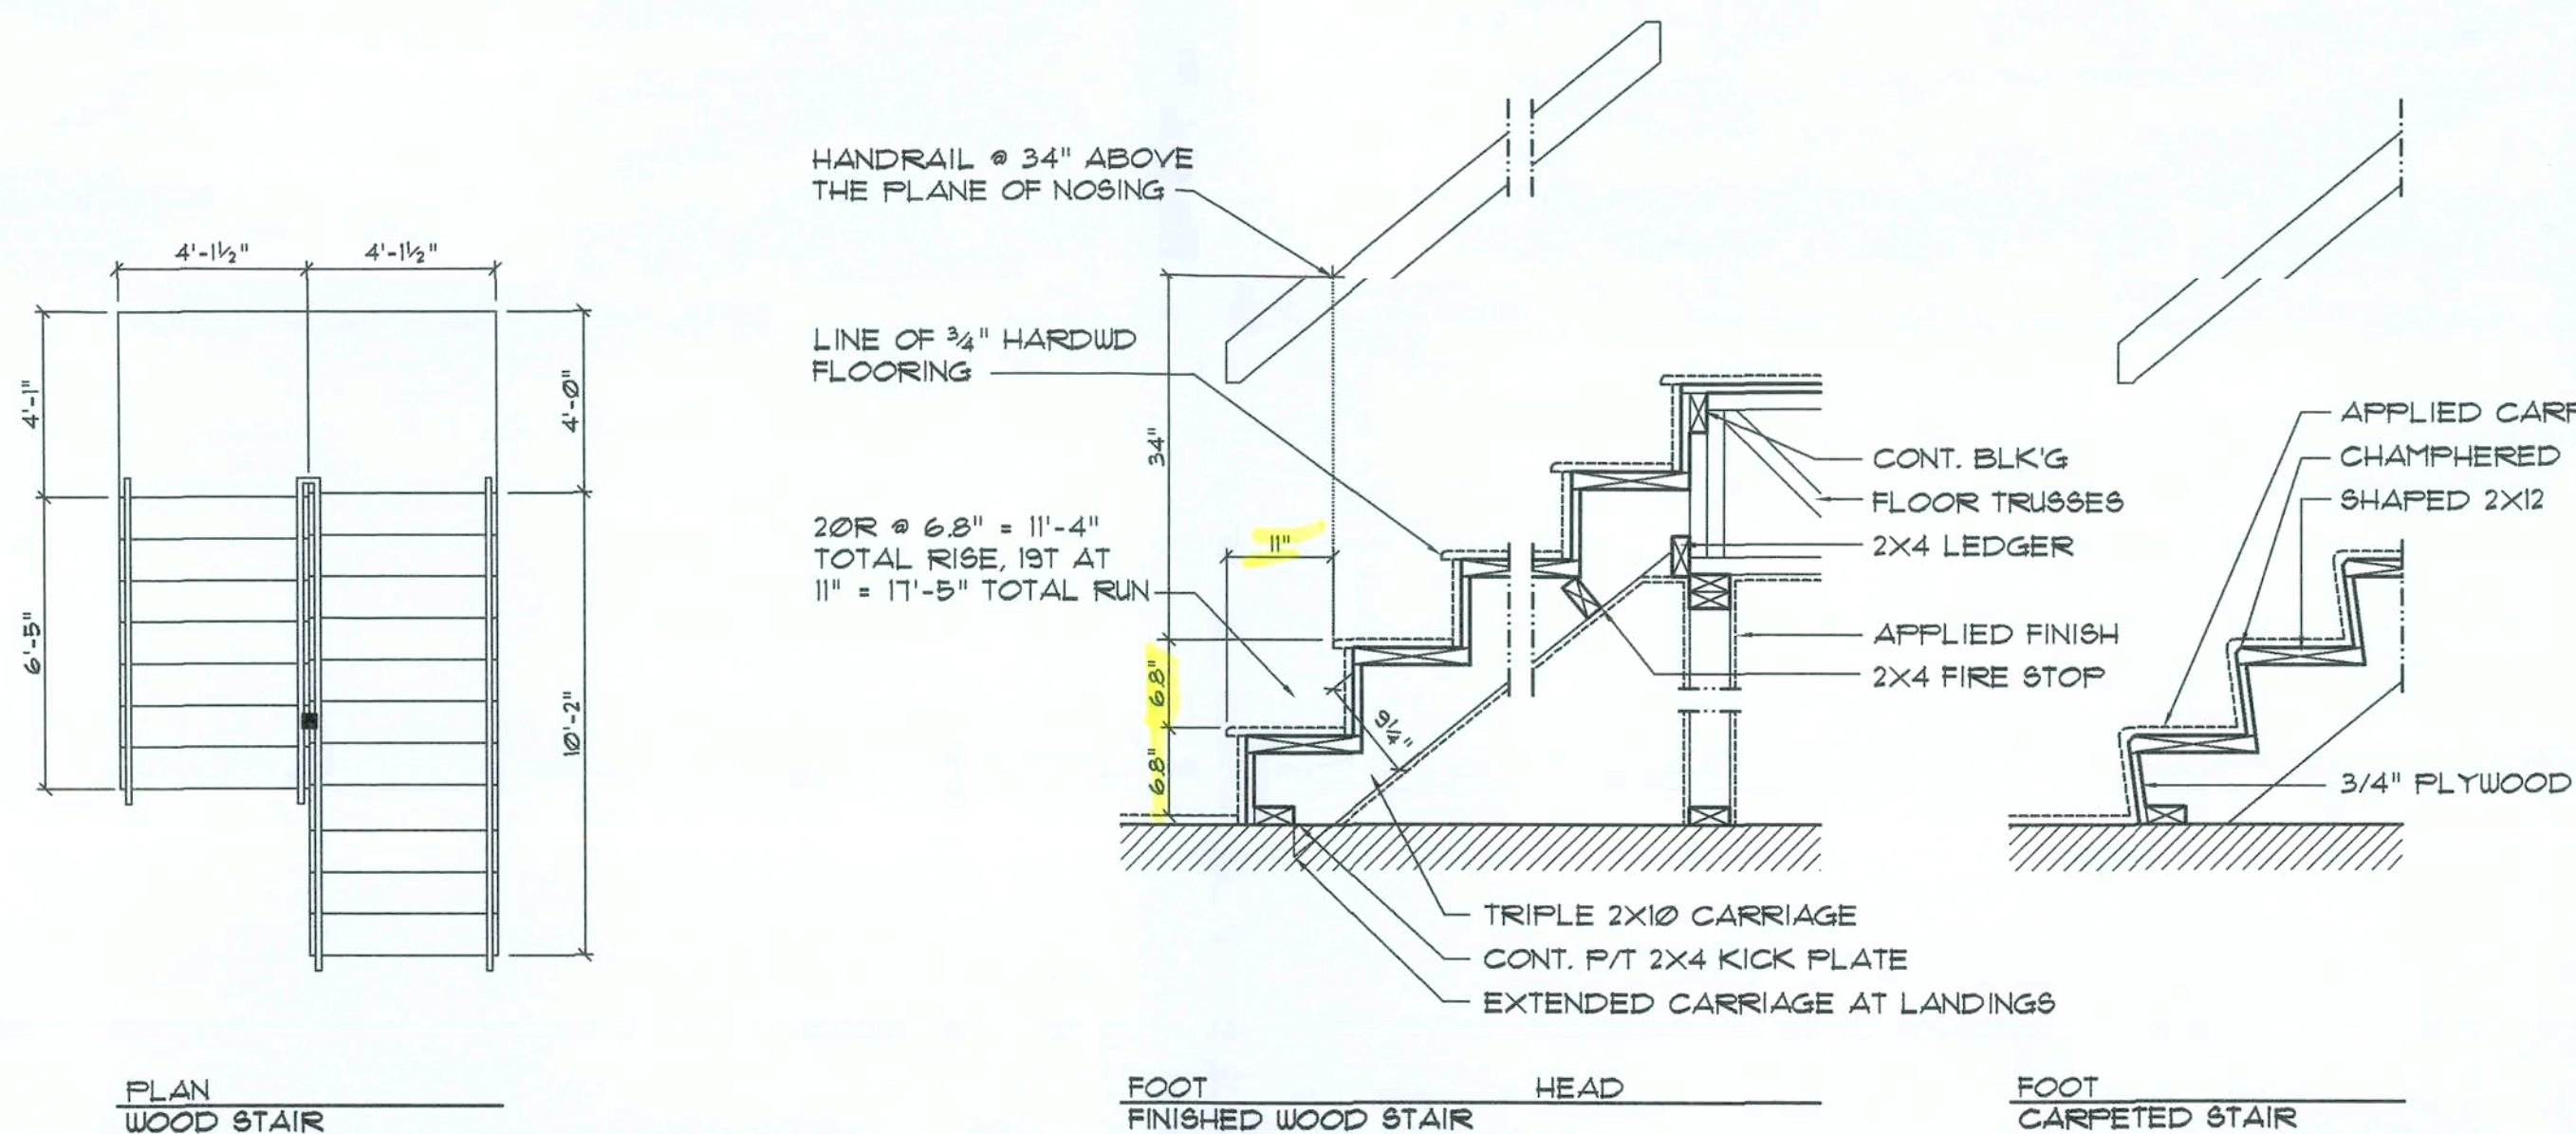

Interior Wood Stair DETAIL

SCALE: 3/4" = 1'-0"

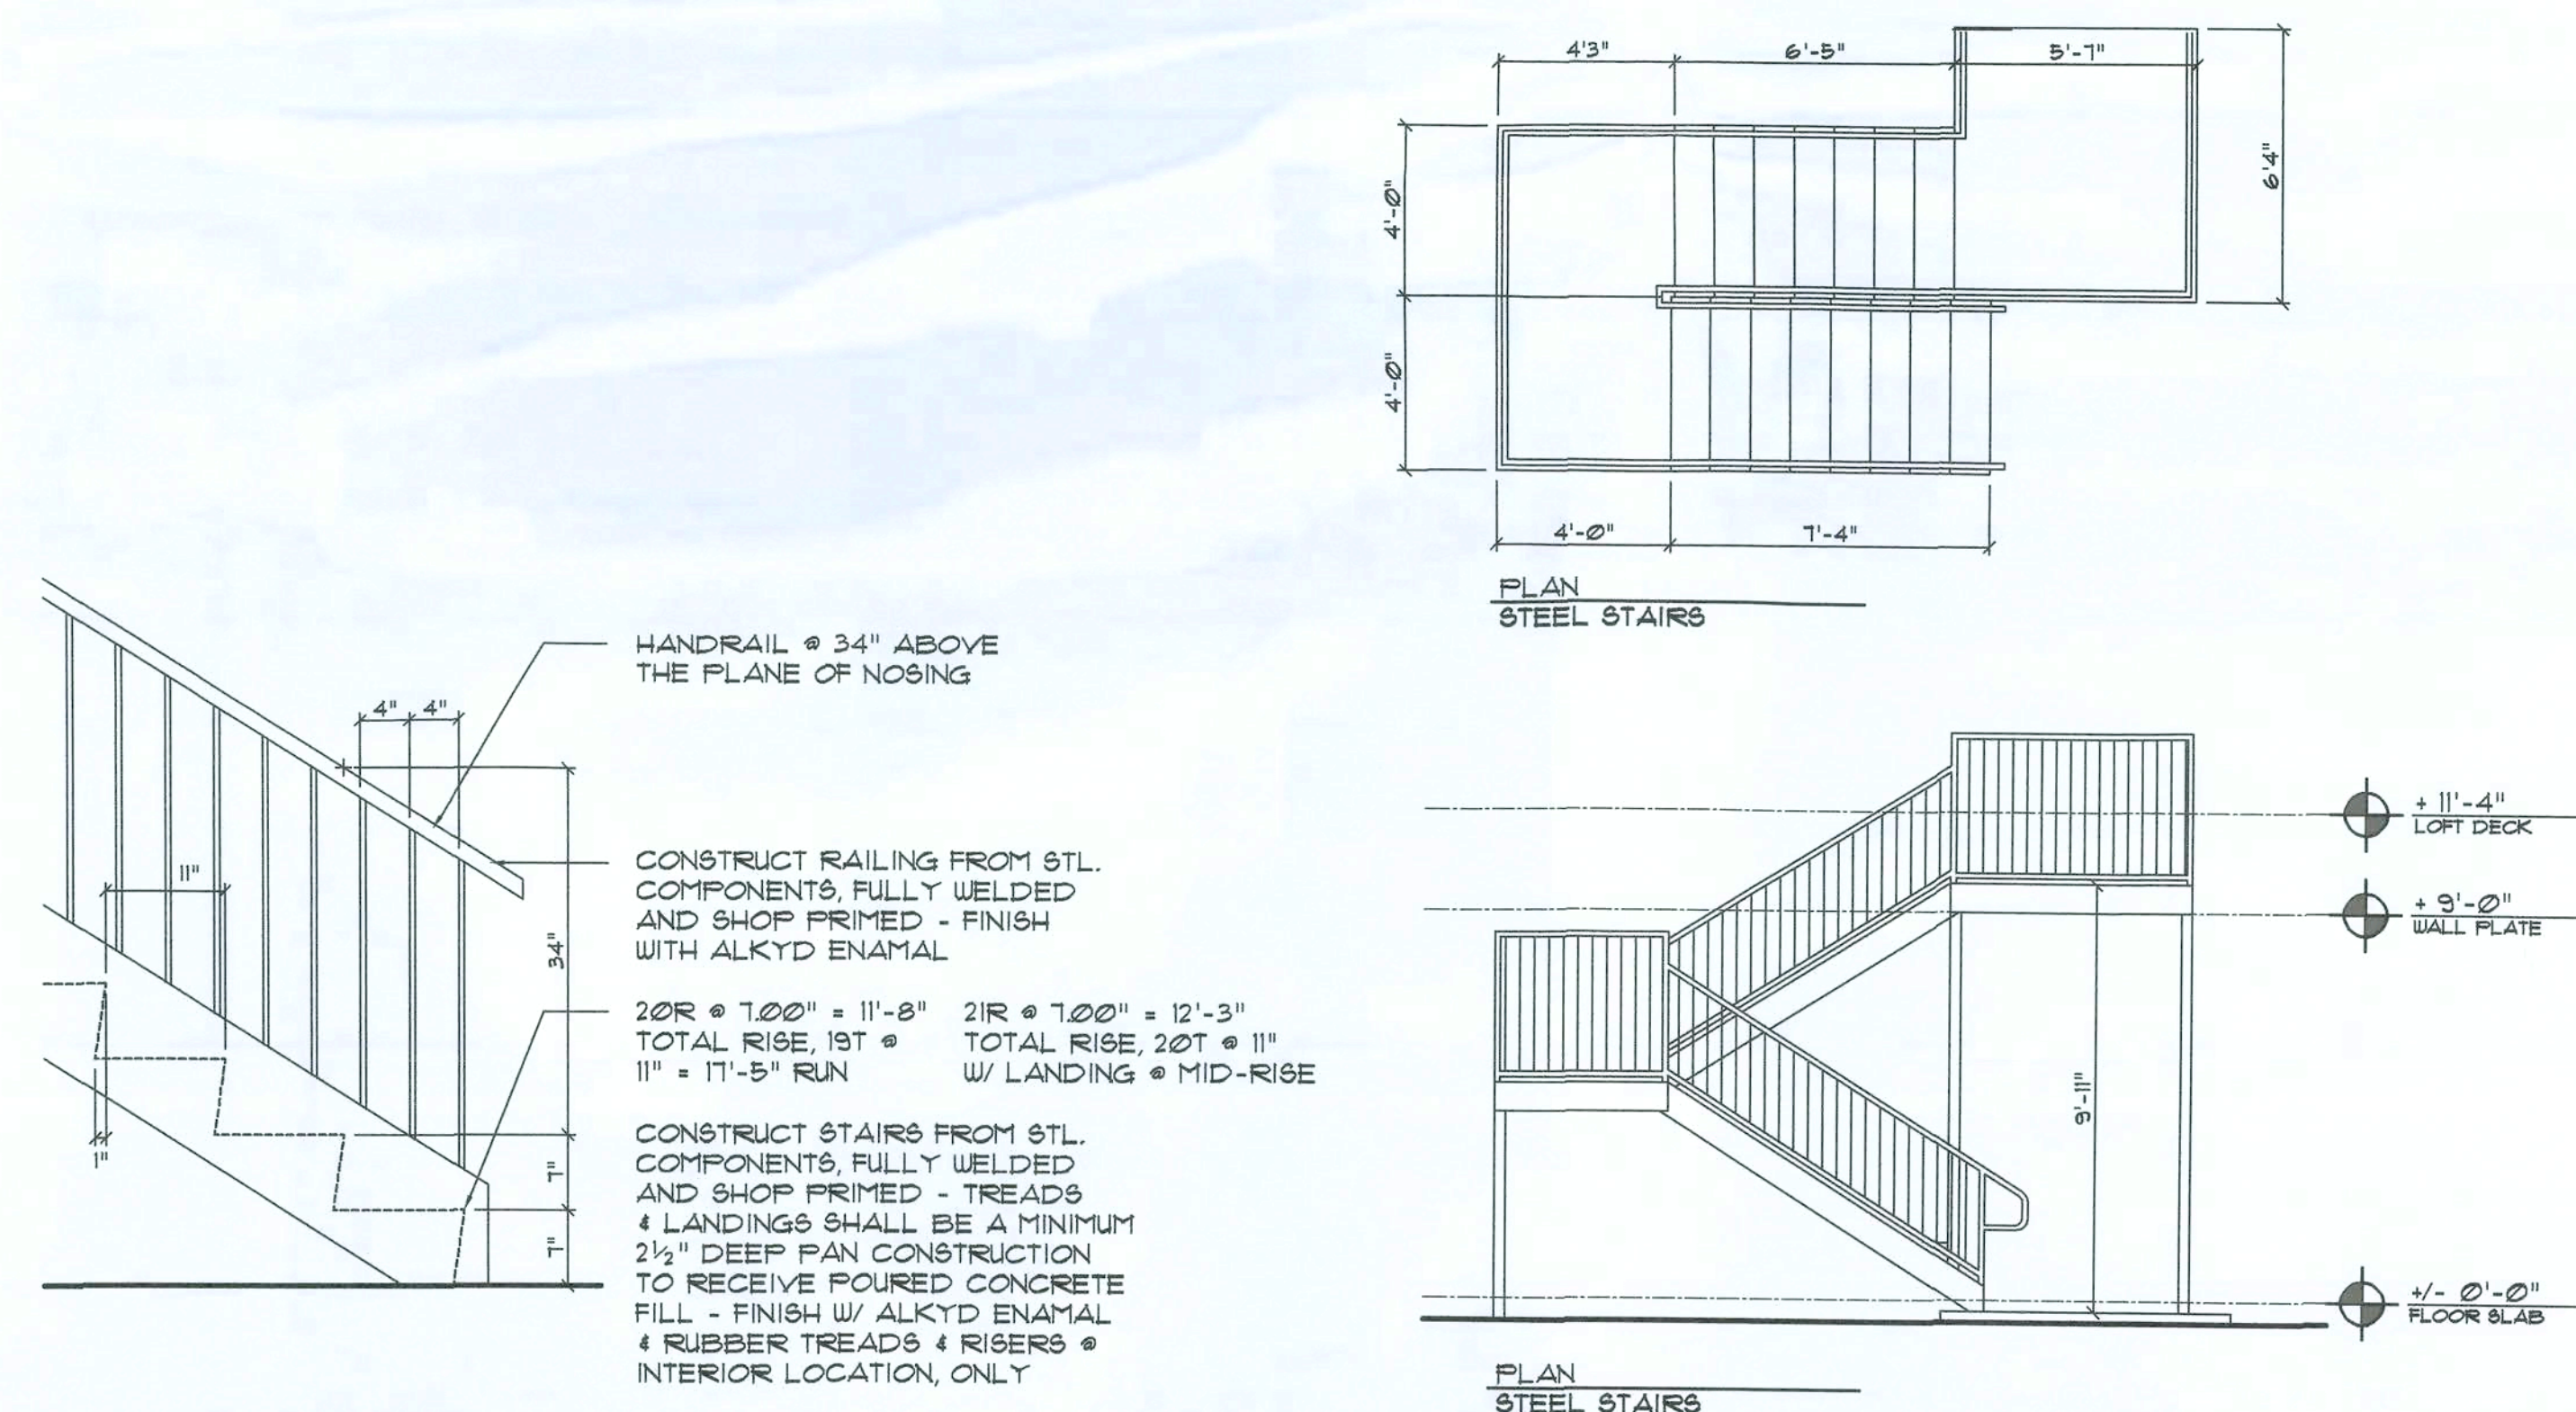

Exterior Steel Stair DETAIL

SCALE: 3/4" = 1'-0"

These drawings, as instruments of service, are the sole property of the architect, and may not be used, copied or reproduced in whole or in part for use on an incorporated within any other job without specific and individual authorization by the architect.

GENERAL INTERIOR FINISH SCHEDULE:

FLOOR AREA: CARPET AND PAD, PATTERN & COLOR AS PER THE OWNER OR LAMINATE STRIP WOOD - SEE OWNER FOR CHANGES

KITCHEN FLOOR AREA: THINSET QUARRY TILE OR SHEET VINYL, PAT. & COLOR AS SELECTED BY THE OWNER

R/R FLOOR AREA: THINSET CERAMIC TILE OR SHEET VINYL, PAT. & COLOR AS SELECTED BY THE OWNER

BASE: TRIM AS PER DETAIL ON A6, COLOR AS SELECTED BY THE OWNER OR CERAMIC TILE OR VINYL - MATCH WITH FLOORING

TRIM: COVES, CROUNES, CASINGS, CHAIRRAILS AND THE LIKE AS PER DETAIL ON A6, STAIN & VARNISH OR PAINT COLOR AS SELECTED BY THE OWNER

WALLS: 1/2" GIB, PRIME AND PAINTED 2 COATS LATEX WALL PAINT, COLOR & GLOSS AS SELECTED BY THE OWNER

MAIN CEILING: 5/8" GIB, DIRECT HUNG, TAFED & FINISHED, W/ 2 COATS OF LATEX CEILING PAINT, COLOR & GLOSS AS SELECTED BY THE OWNER

APPLIED FINISHES: APPLIED FINISH TO GIB, 16 SPRAY, KNOCK-DOWN SKIP-TROU AND SIMILAR TREATMENTS AS DIRECTED BY THE OWNER

CABINETS: AS SELECTED BY THE OWNER, MINIMUM AFI GRADE, "CUSTOM" - ALL COUNTERTOPS SHALL BE AS SELECTED BY THE OWNER

REVISION:
02 SEP 2020

Copyright, 2020 ©
N.P. Gesler, Architect

DRAWN
mg

ASSISTED LIVING FACILITY for
SMITH - SORENSEN
LAKE CITY, COLUMBIA COUNTY, FLORIDA
FLOOR PLAN

Calculating Service
48 Years of Experience
1972 - 2020
N.P. Gesler, Architect
AR000000

NICHOLAS PAUL GERSELT
ARCHITECT
N.C.A.R.B. Certified
1726 NW Brown Rd.
Lake City, FL 33605
386-368-4355

DATE:
18 AUG 2020

COMM:
2K2040

SHEET

A3

5 OF 11


AR007005

Digitally signed by N.P. GESLER
DN: cn = N. P. GESLER, c = US
o = AR0007005, ou = ARCHITECT
Date: 2020.08.18 15:45:45 -0400

PUBLIC TOILET ROOM ACCESSORIES			
MANUF.	ITEM	MODEL N.	COMMENTS
BRADLEY	PAPER TOWEL DISP.	2494	SURFACE MOUNTED, 48" AFF, BATTERY OPERATION
BOBRICK	HANDICAP RAILING	B-5026.99-36	PEENED GRIP SURFACES
BOBRICK	TOILET TISSUE DISP.	B-2092	JUMBO DUAL ROLL - 30" AFF. TO TOP
BOBRICK	SOAP DISP.	B-2111	50 1/8" AFF. TO TOP
-	MIRROR	-	WALL MNT. VANITY TO RECEIVE FULL MIRROR

BOBRICK WASHROOM ACCESSORIES
2000 COMMERCIAL DRIVE
CLIFTON PARK, NY 12065-1350
518-871-1444
www.bobrick.com

NOTE: MANUFACTURERS LISTED ARE FOR BASIS OF COMPARISON FOR "AS EQUAL" PRODUCTS. OTHER MANUFACTURER'S PRODUCTS MAY BE SUBSTITUTED WITH ARCHITECT'S APPROVAL FOR PRODUCTS MEETING OR EXCEEDING THE SPECIFICATIONS FOR THOSE LISTED IN THE SCHEDULE, ABOVE.

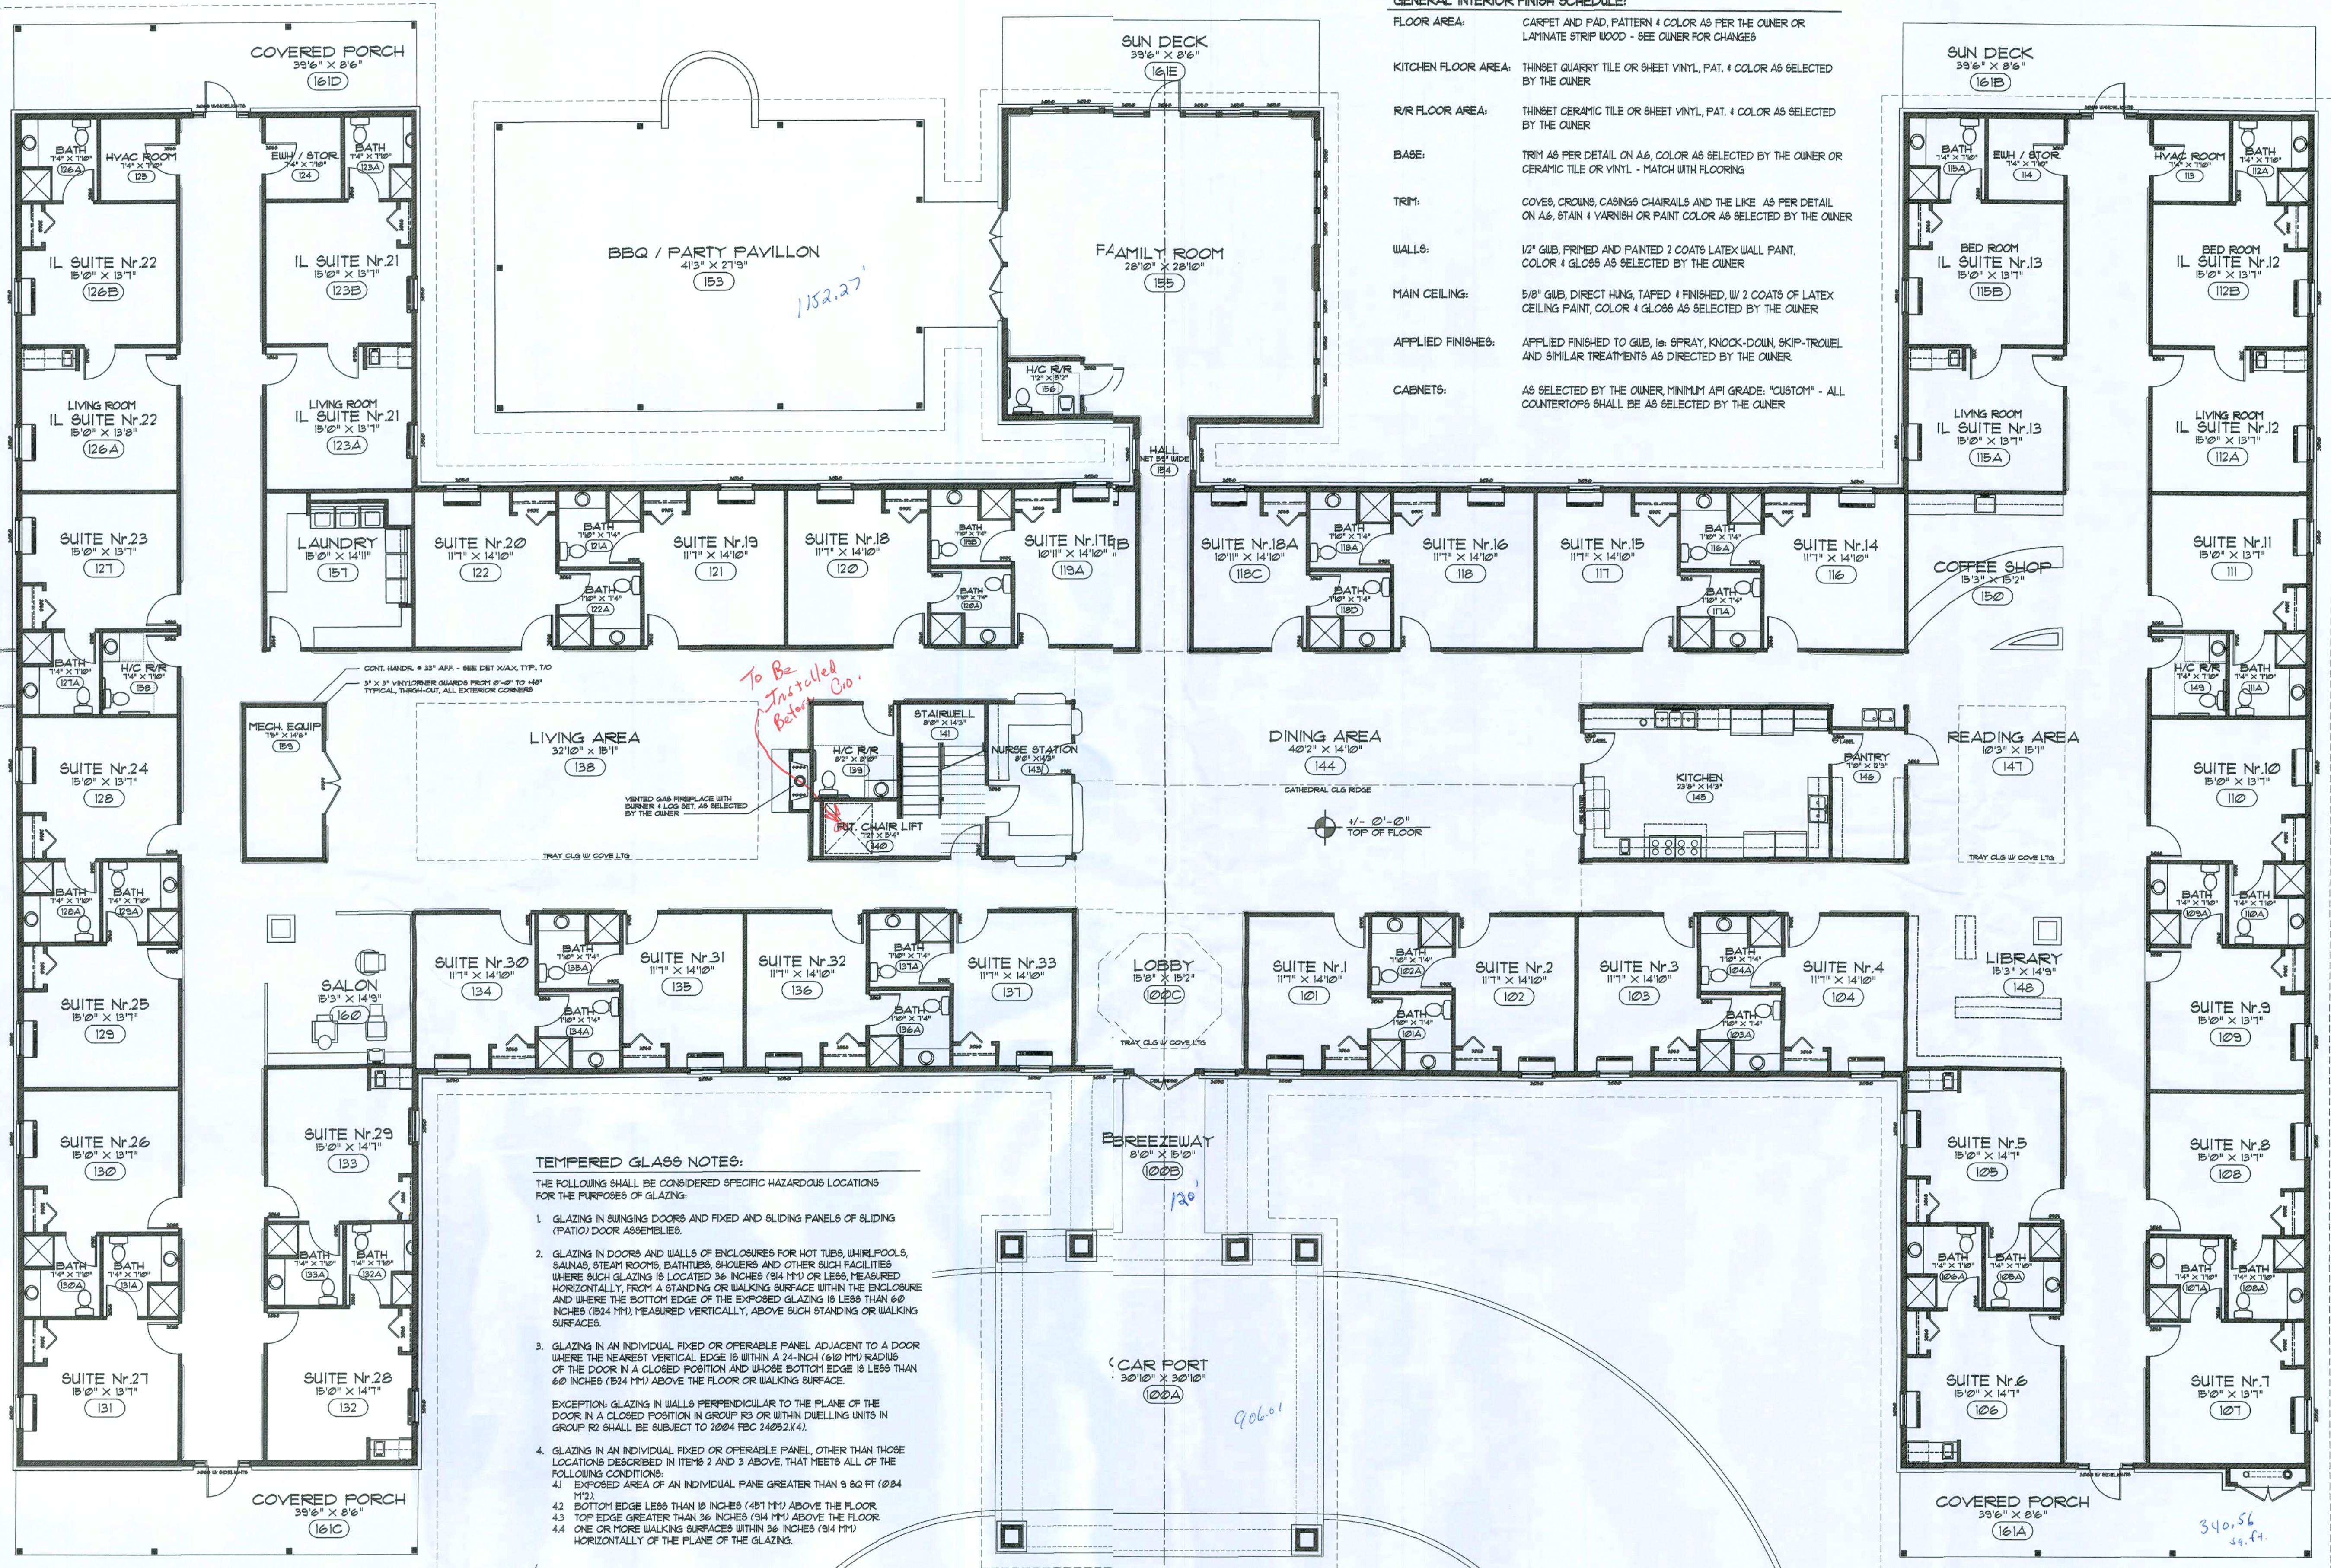

TEMPERED GLASS NOTES:

THE FOLLOWING SHALL BE CONSIDERED SPECIFIC HAZARDOUS LOCATIONS FOR THE PURPOSES OF GLAZING:


- GLAZING IN SWINGING DOORS AND FIXED AND SLIDING PANELS OF SLIDING (PATIO) DOOR ASSEMBLIES.
- GLAZING IN DOORS AND WALLS OF ENCLOSURES FOR HOT TUBS, WHIRLPOOLS, SAUNAS, STEAM ROOMS, BATHTUBS, SHOWERS AND OTHER SUCH FACILITIES WHERE SUCH GLAZING IS LOCATED 36 INCHES (914 MM) OR LESS, MEASURED HORIZONTALLY, FROM A STANDING OR WALKING SURFACE WITHIN THE ENCLOSURE AND WHERE THE BOTTOM EDGE OF THE EXPOSED GLAZING IS LESS THAN 60 INCHES (1524 MM) MEASURED VERTICALLY, ABOVE SUCH STANDING OR WALKING SURFACES.
- GLAZING IN AN INDIVIDUAL FIXED OR OPERABLE PANEL ADJACENT TO A DOOR WHERE THE NEAREST VERTICAL EDGE IS WITHIN A 24-INCH (610 MM) RADIUS OF THE DOOR IN A CLOSED POSITION AND WHERE BOTTOM EDGE IS LESS THAN 60 INCHES (1524 MM) MEASURED VERTICALLY, ABOVE SUCH STANDING OR WALKING SURFACES.
EXCEPTION: GLAZING IN WALLS PERPENDICULAR TO THE PLANE OF THE DOOR IN A CLOSED POSITION IN GROUP R3 OR WITHIN DUELLING UNITS IN GROUP R2 SHALL BE SUBJECT TO 2004 IBC 2405.2(4).
- GLAZING IN AN INDIVIDUAL FIXED OR OPERABLE PANEL, OTHER THAN THOSE LOCATIONS DESCRIBED IN ITEMS 2 AND 3 ABOVE, THAT MEETS ALL OF THE FOLLOWING CONDITIONS:
 - EXPOSED AREA OF AN INDIVIDUAL PANE GREATER THAN 9 SQ FT (824 MM²).
 - BOTTOM EDGE LESS THAN 18 INCHES (457 MM) ABOVE THE FLOOR.
 - TOP EDGE GREATER THAN 36 INCHES (914 MM) ABOVE THE FLOOR.
 - ONE OR MORE WALKING SURFACES WITHIN 36 INCHES (914 MM) HORIZONTALLY OF THE PLANE OF THE GLAZING.

FLOOR PLAN

SCALE: 1/8" = 1'-0"

10 20 30 40
GRAPHIC SCALE

These drawings, as instruments of service, are the sole property of the architect, and may not be used, copied or reproduced in whole or in part for use on or incorporated within any other job without specific and individual authorization by the architect.

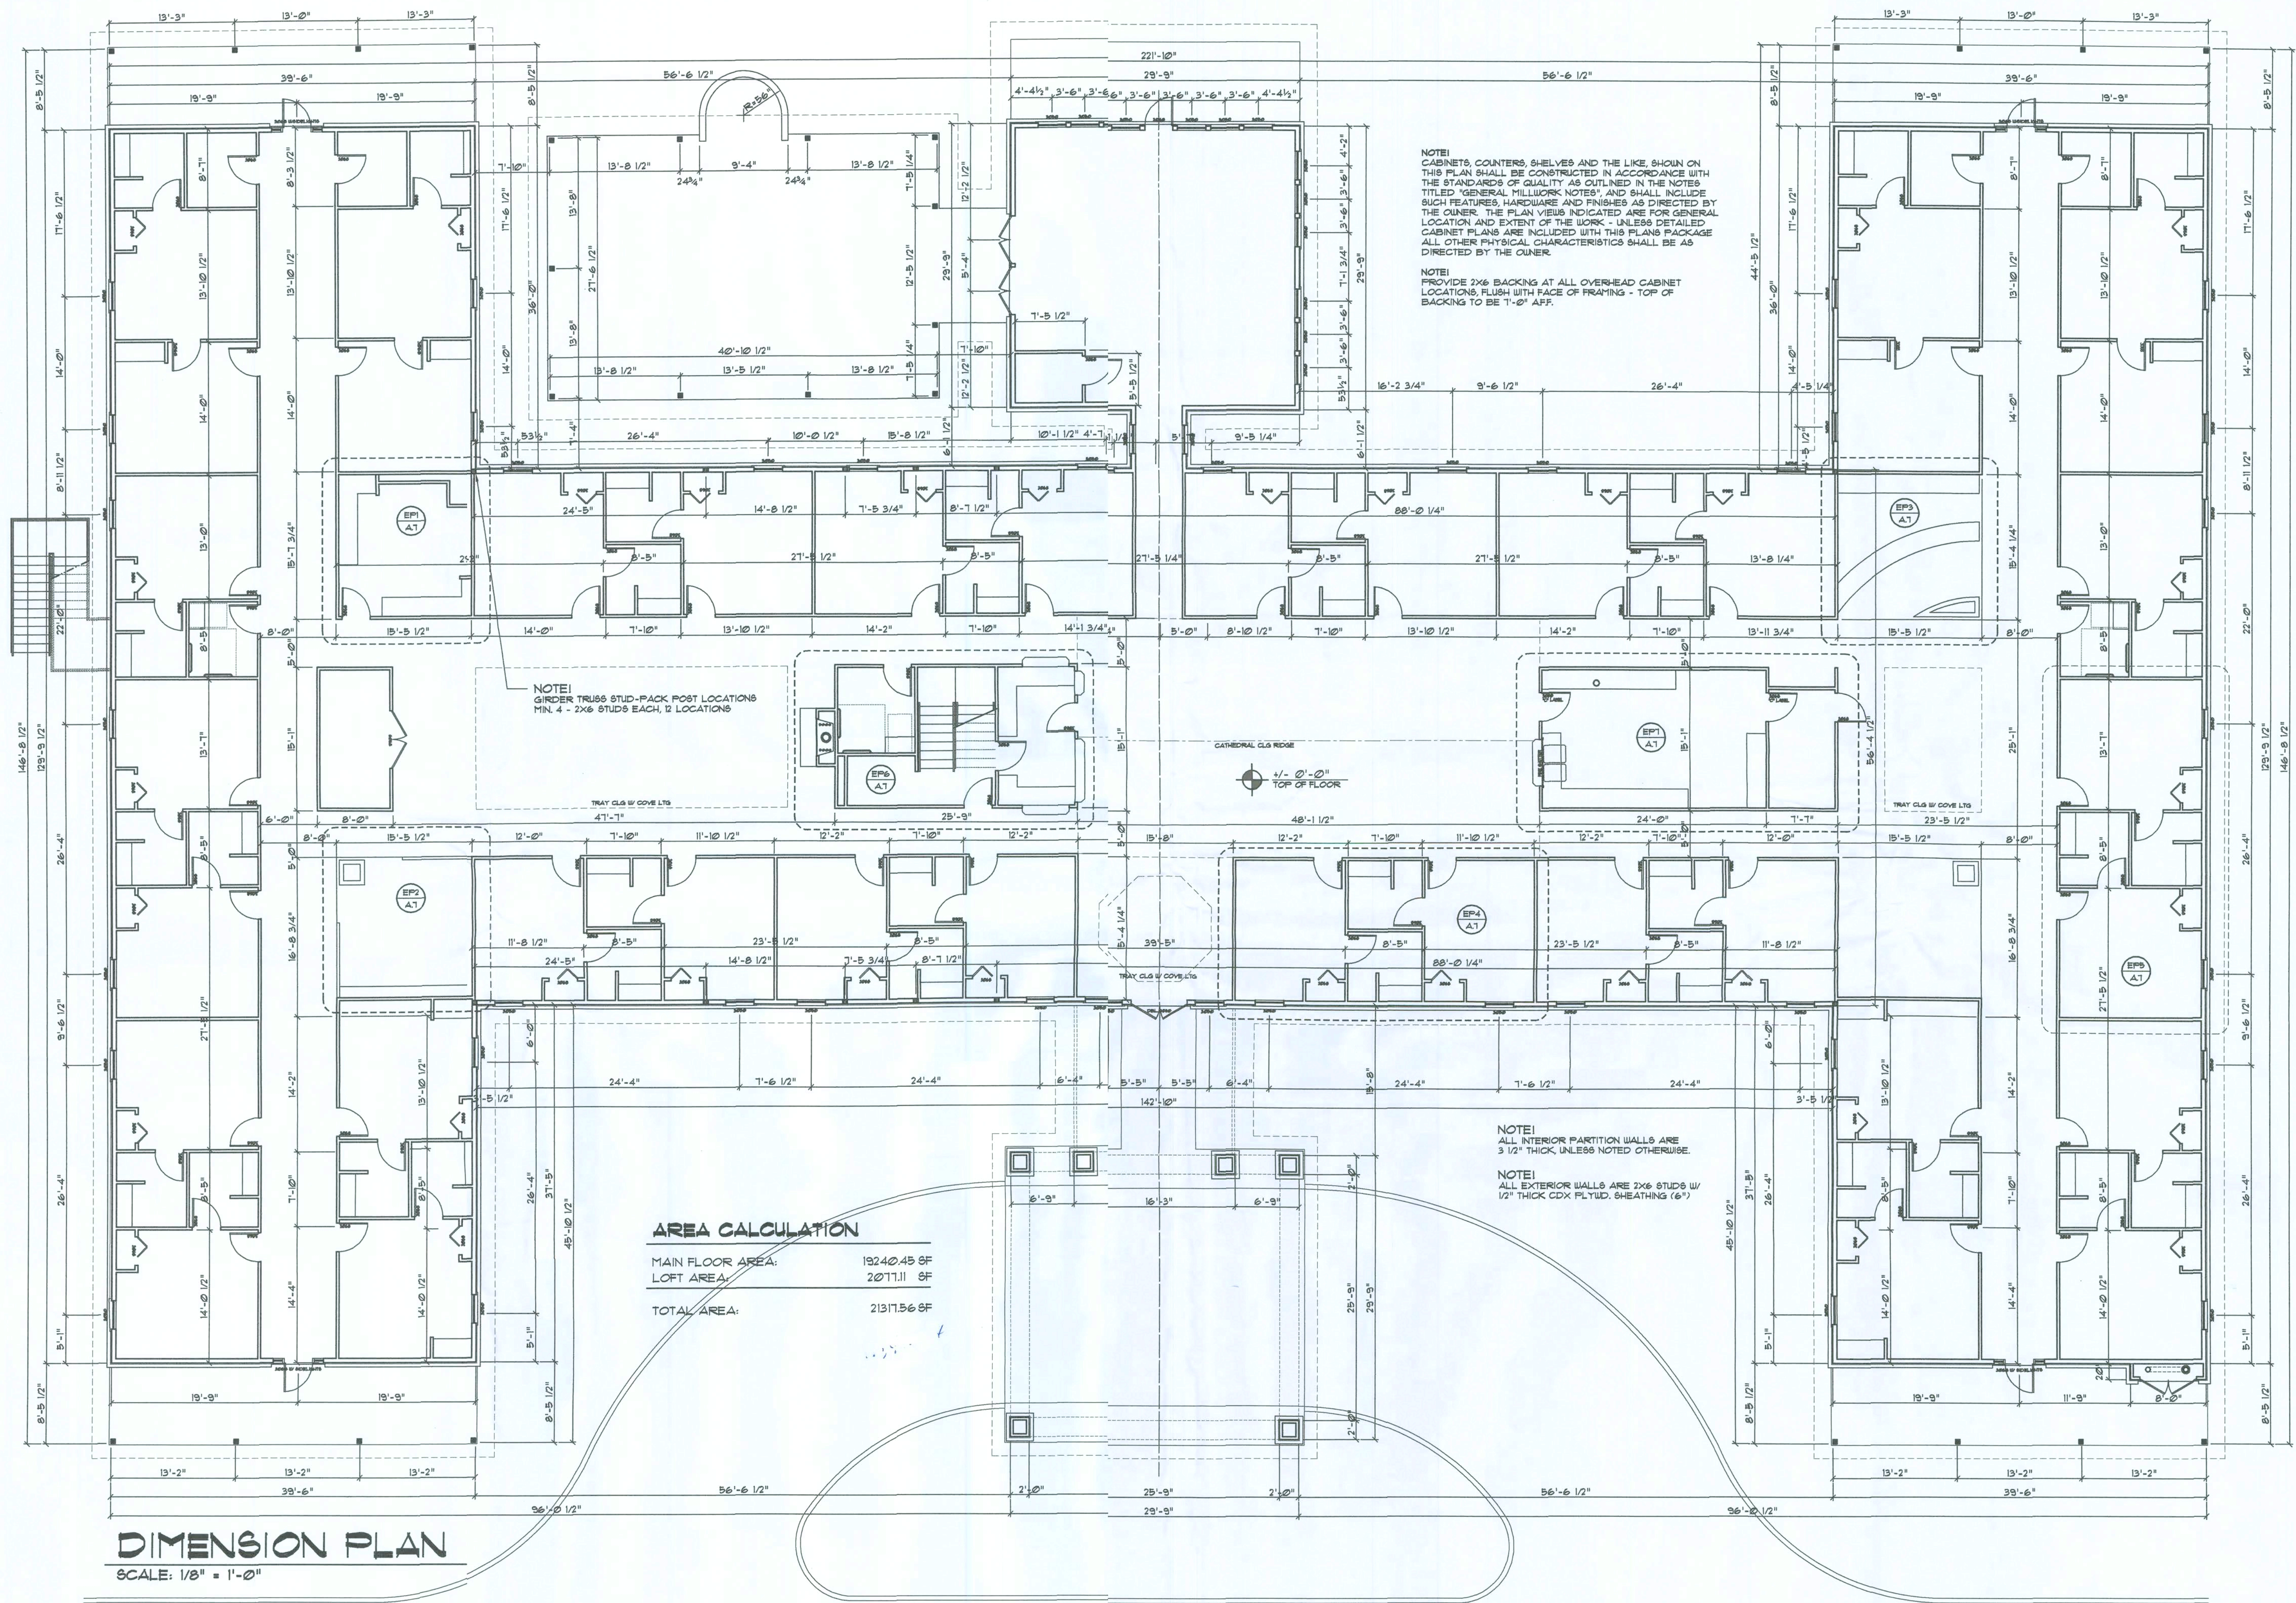

REVISION:
02 SEP 2020
08 SEP 2020

Copyright 2020
N.J. Gesler, Architect

DRAWN:
mg

ASSISTED LIVING FACILITY for
SMITH - SORENSEN
LAKE CITY, COLUMBIA COUNTY, FLORIDA
DIMENSION PLAN

Celebrating
48 Years of Service
1972-2020
N.J. Gesler, Architect
AR0007005


**NICHOLAS
GESLER
ARCHITECT**
17558 NW Brown Rd.,
356-362-4305
N.C.A.R.B. Certified

DATE
18 AUG 2020
CONTRACT
22040

SHEET:
A.4
4 OF 11

AR0007005

These drawings, as instruments of service, and the sole property of the architect, and may not be used, copied or reproduced in whole or in part for use on or incorporated within any other job without specific and individual authorization by the architect.

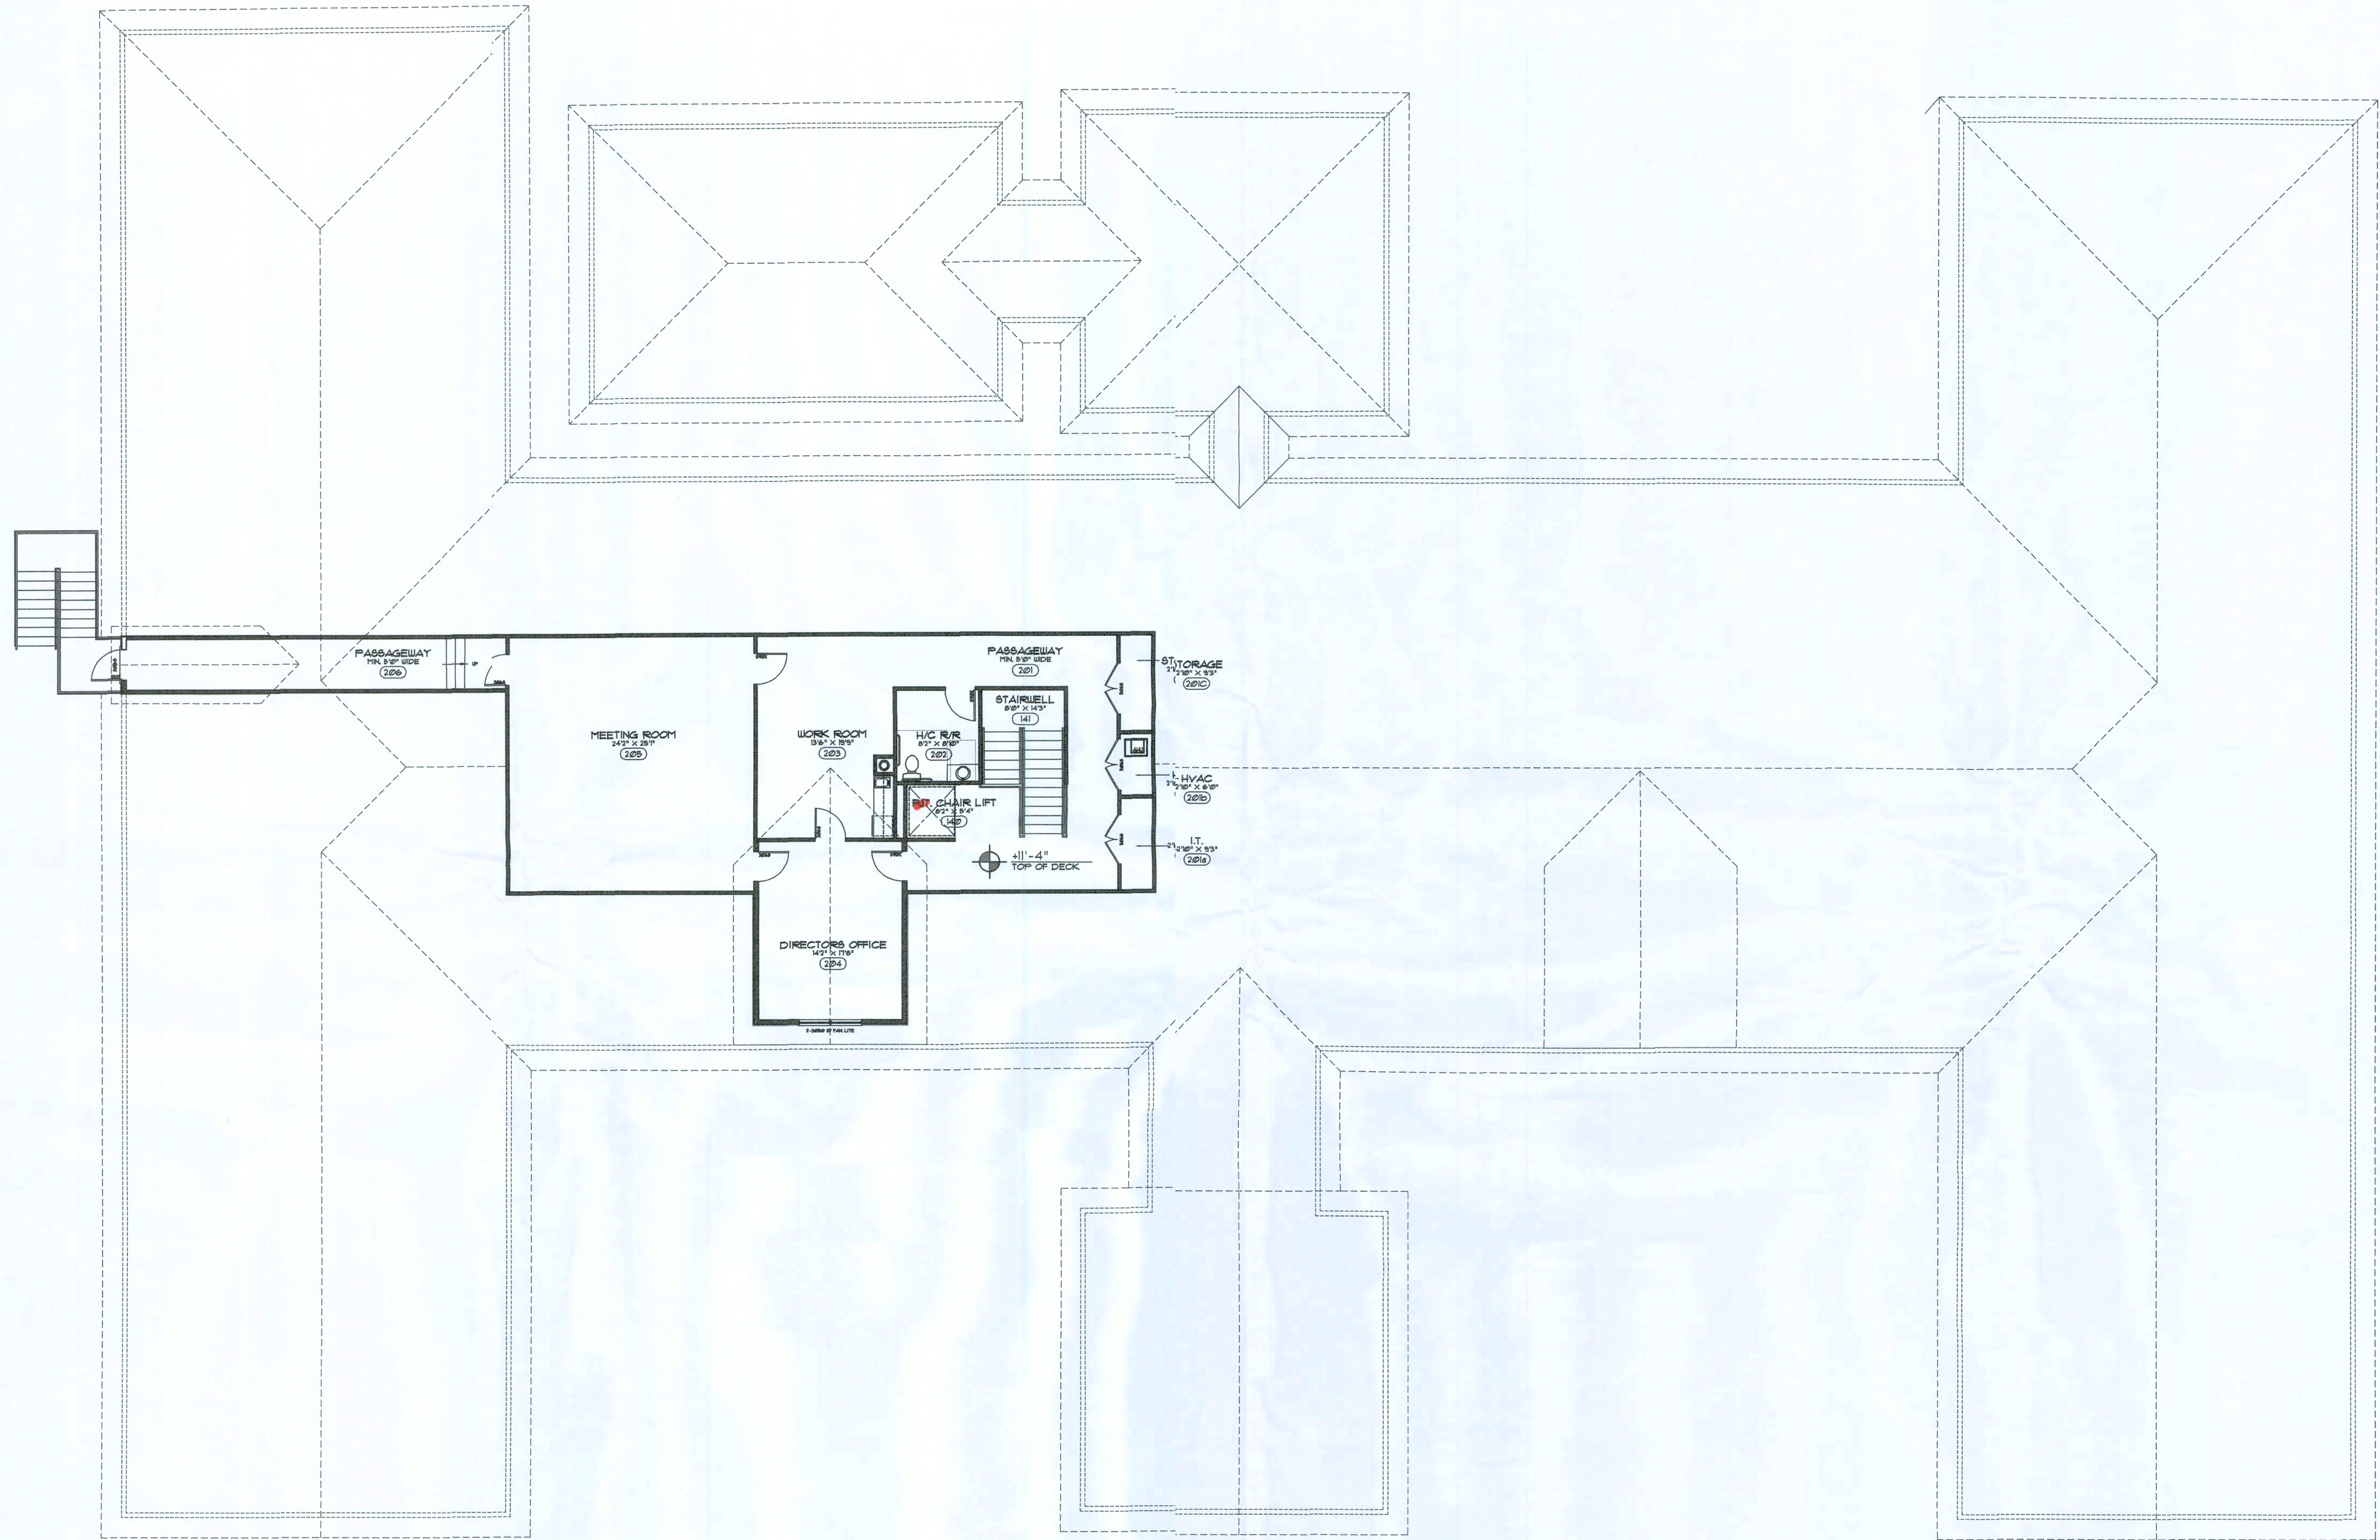

LOFT PLAN
SCALE: 1/8" = 1'-0"

GRAPHIC SCALE
0 10 20

Digitally signed by N.P. GESLER
DN: CN = N. P. GESLER C = US
O = AR0007005 GUP ARCHITECT
Date: 2020.08.13 10:04:03 -05'00'

REVISION:

Copyright 2020
N.P. Gesler, Architect

DRAWN:
npg

ASSISTED LIVING FACILITY for
SMITH - SORENSEN
LAKE CITY, COLUMBIA COUNTY, FLORIDA
LOFT PLAN

Professional Seal
1972 - 2020
N.P. Gesler, Architect
00000000


**NICHOLAS
GESLER
ARCHITECT**
N.C.A.R.B. Certified
1768 NW Brown Rd.
Lake City, FL 32055
386-365-4355

DATE:
13 AUG 2020
COM#:
K2040

SHEET:
A.5
5 of 11

AR0007005

These drawings, as instruments of service, are the sole property of the architect, and may not be used, copied or reproduced in whole or in part for use on or incorporated within any other job without specific and individual authorization by the architect.

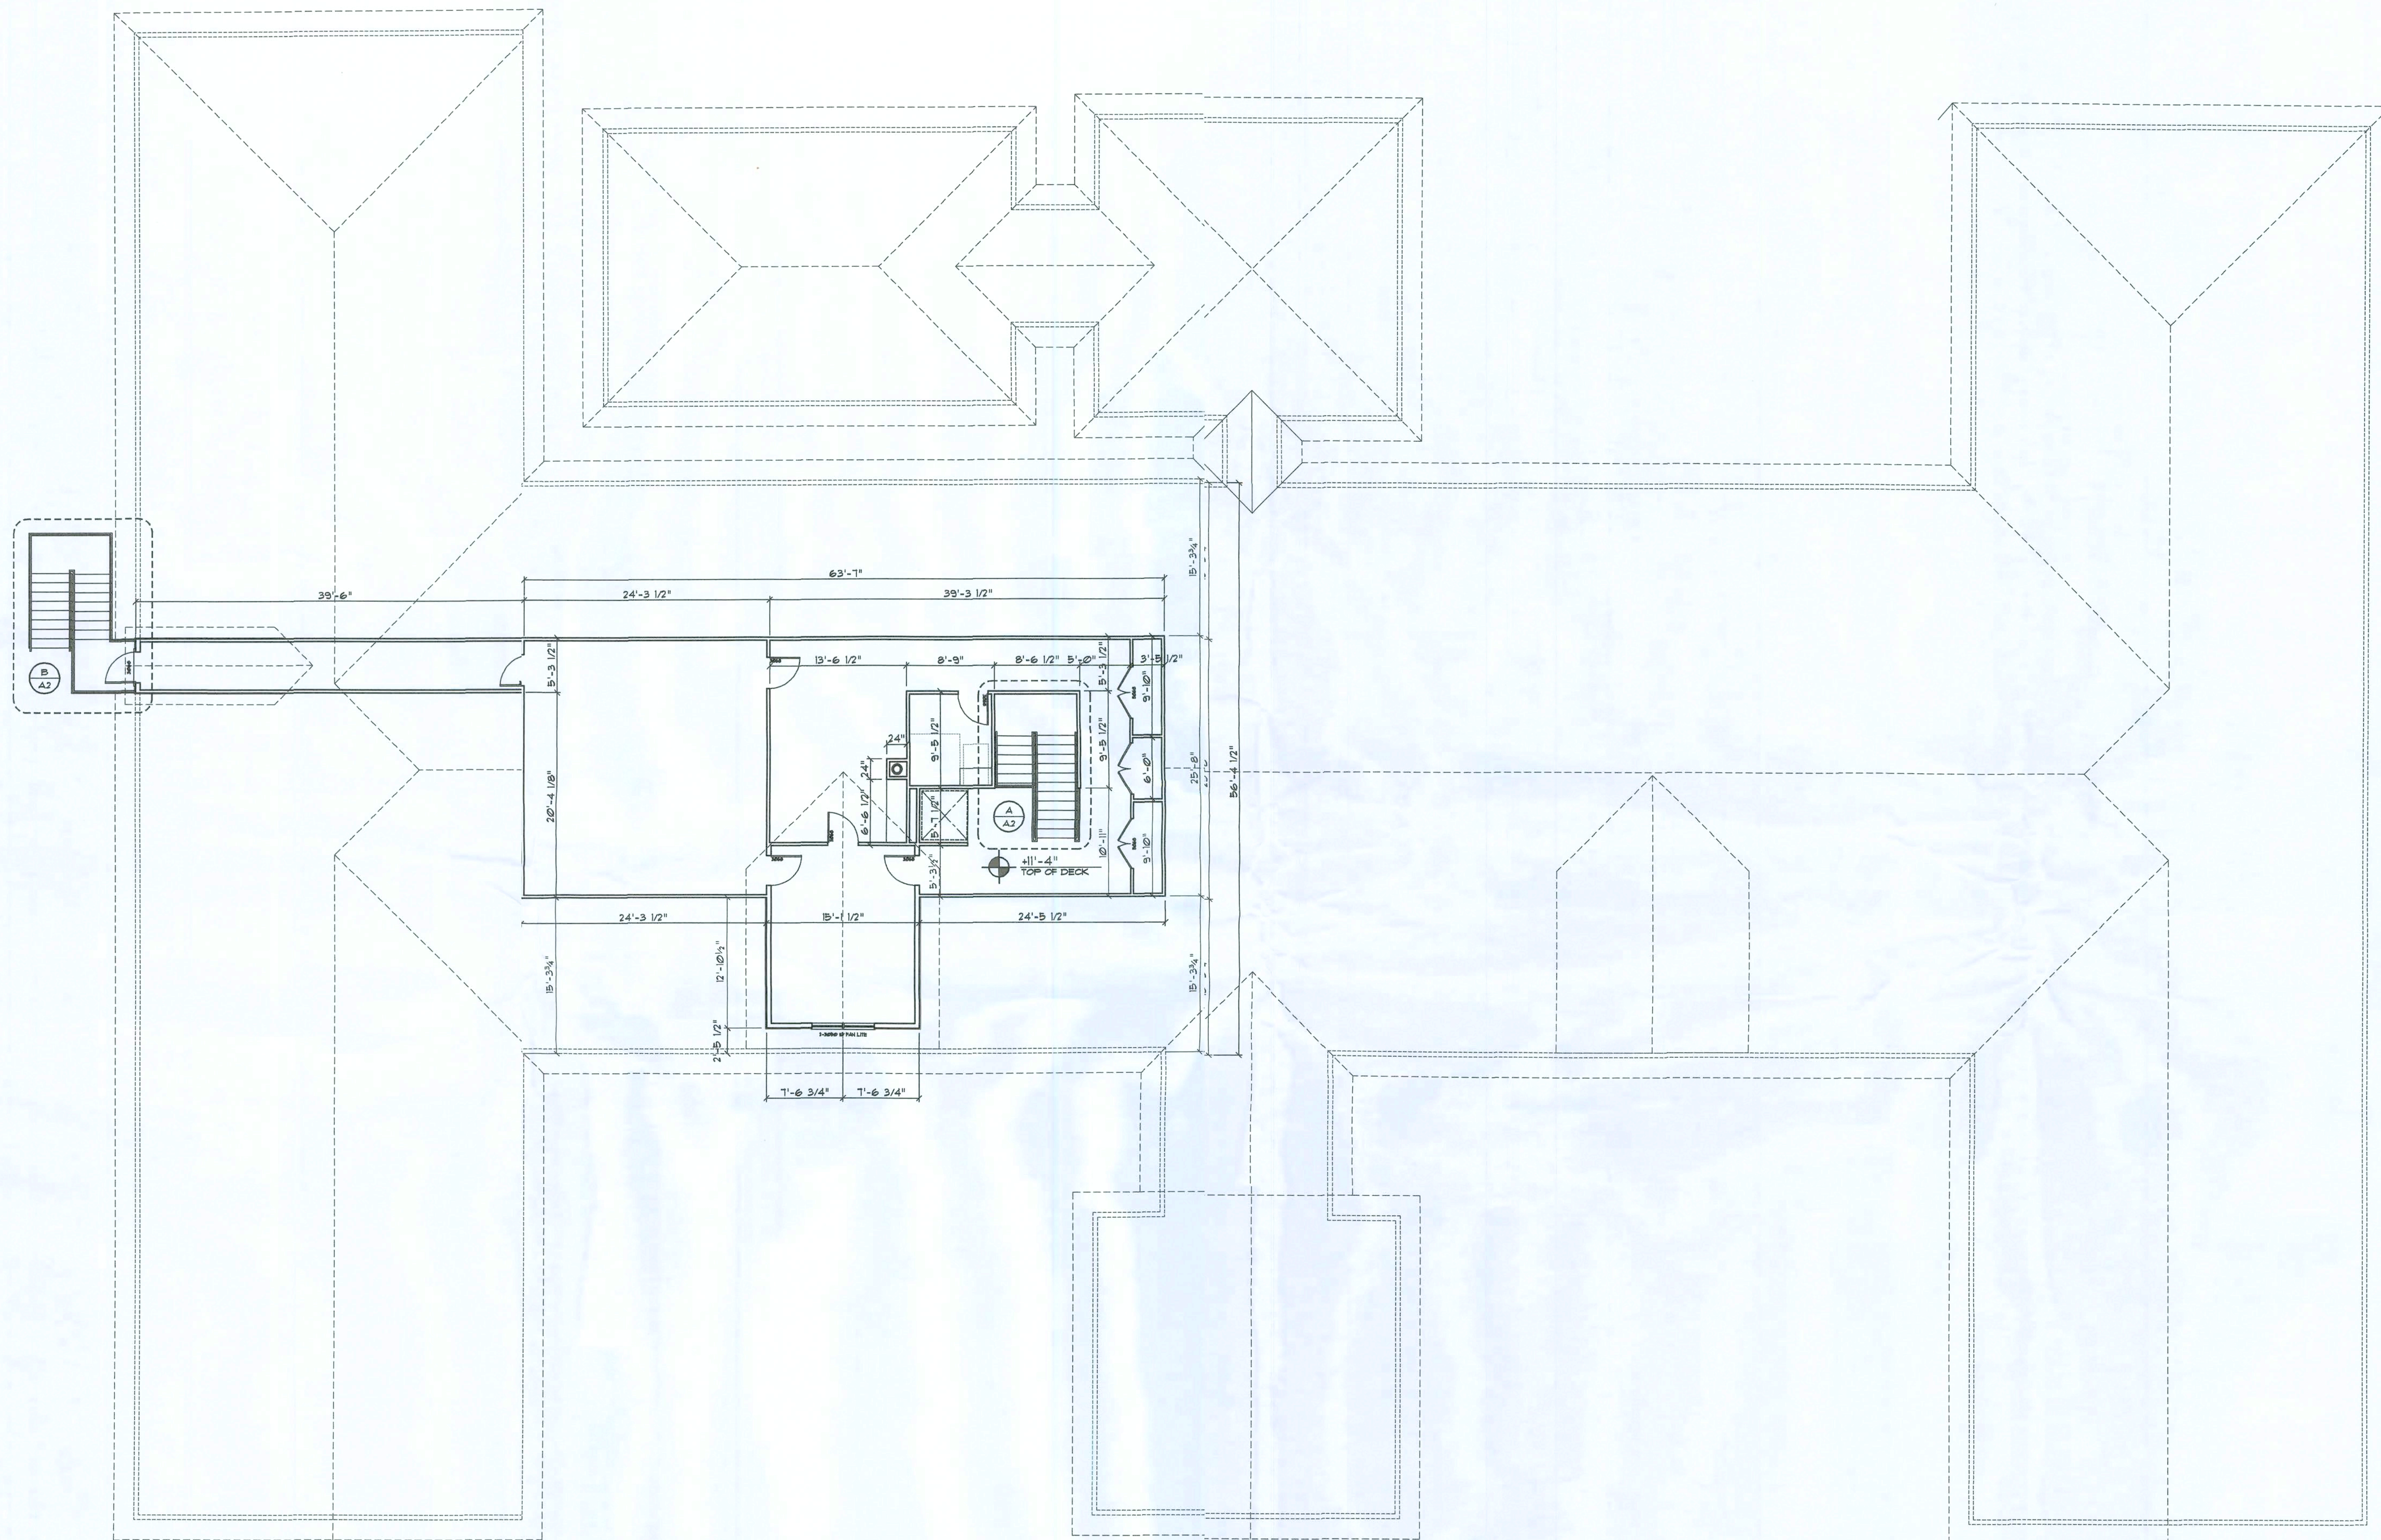

LOFT DIM. PLAN
SCALE: 1/8" = 1'-0"



Digitally signed by: N. P. GEISLER
DN: cn = N. P. GEISLER, o = ARCHITECT
Date: 2020.08.09 09:01:37 -0500

REVISIONS:
02 SEP 2020

Copyright 2020
N. P. Geisler, Architect

DRAWN:
rpg

ASSISTED LIVING FACILITY for
SMITH - SORENSEN
LAKE CITY, COLUMBIA COUNTY, FLORIDA
LOFT DIMENSION PLAN


48 Years of Service
1972 - 2020
N.P. Geisler, Architect
00000005

NICHOLAS PAUL GEISLER ARCHITECT
N.C.A.R.B. Certified
1758 NW Brown Rd.
Lake City, FL 32055
386-368-4355

DATE:
18 AUG 2020
COMM:
2K2040


SHEET:
4.6
6 of 11

AR0007005

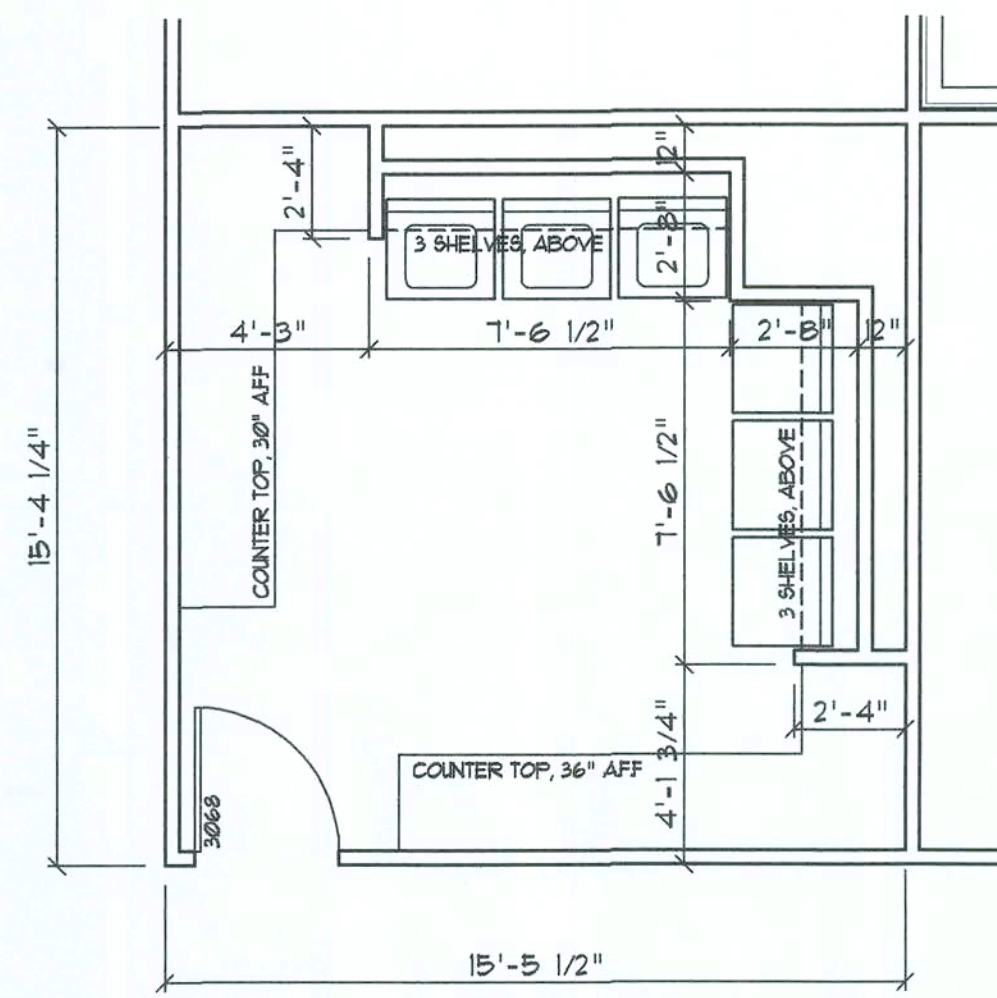


Laundry PLAN
SCALE: 1/4" = 1'-0"

EP1

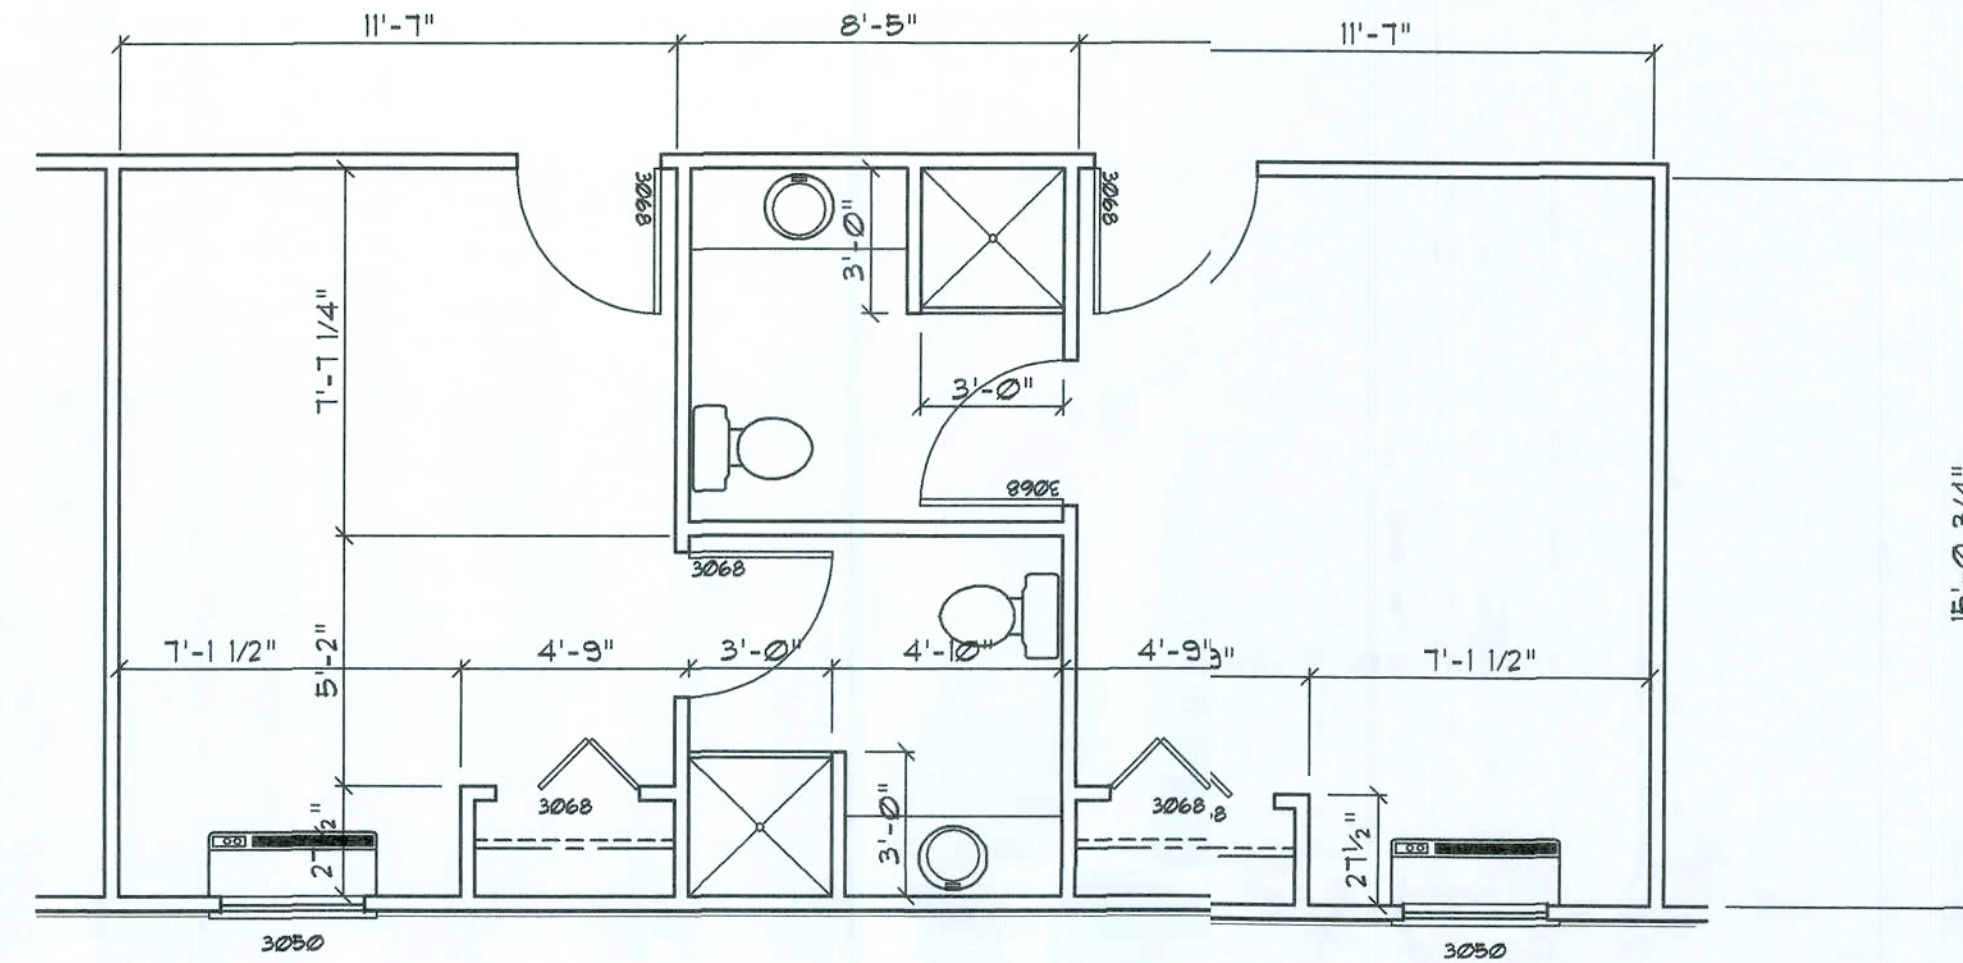


Small Dual Unit PLAN
SCALE: 1/4" = 1'-0"

EP4

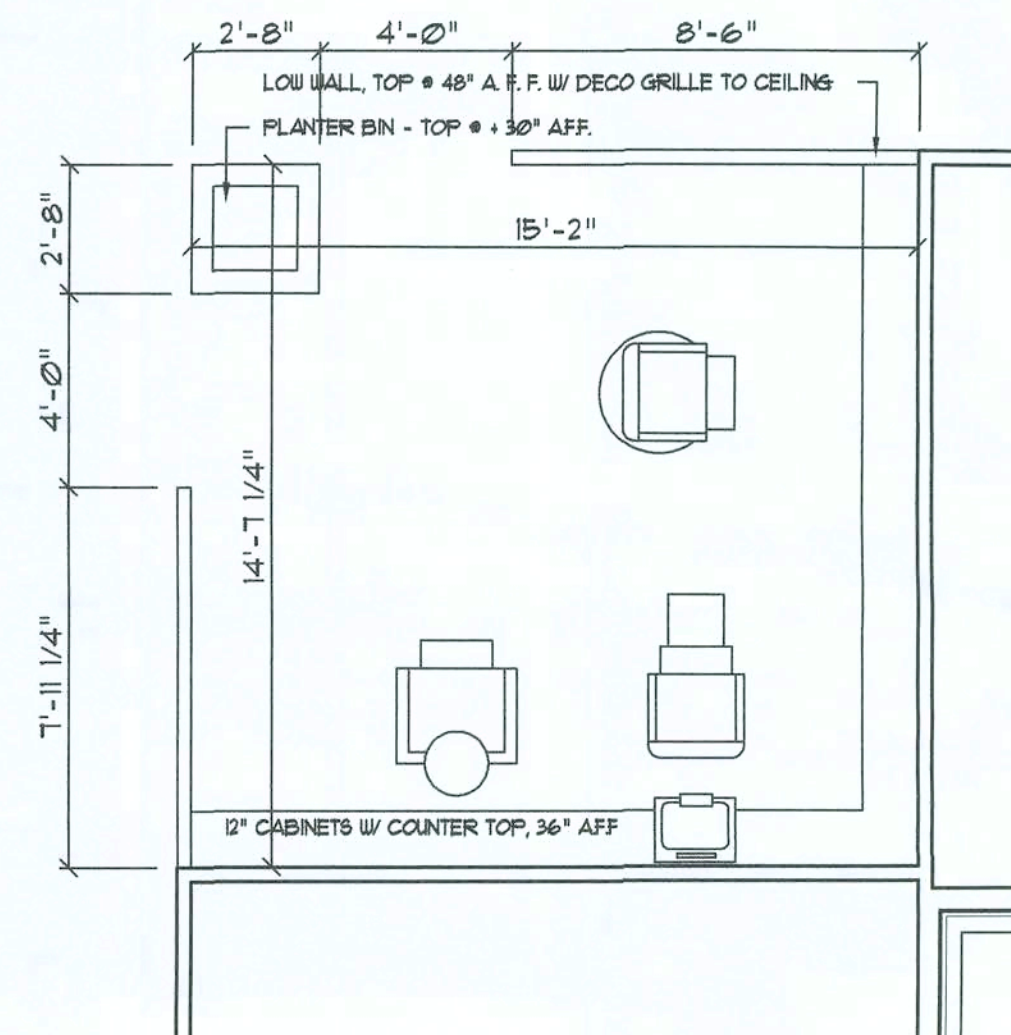


Beauty PLAN
SCALE: 1/4" = 1'-0"

EP2

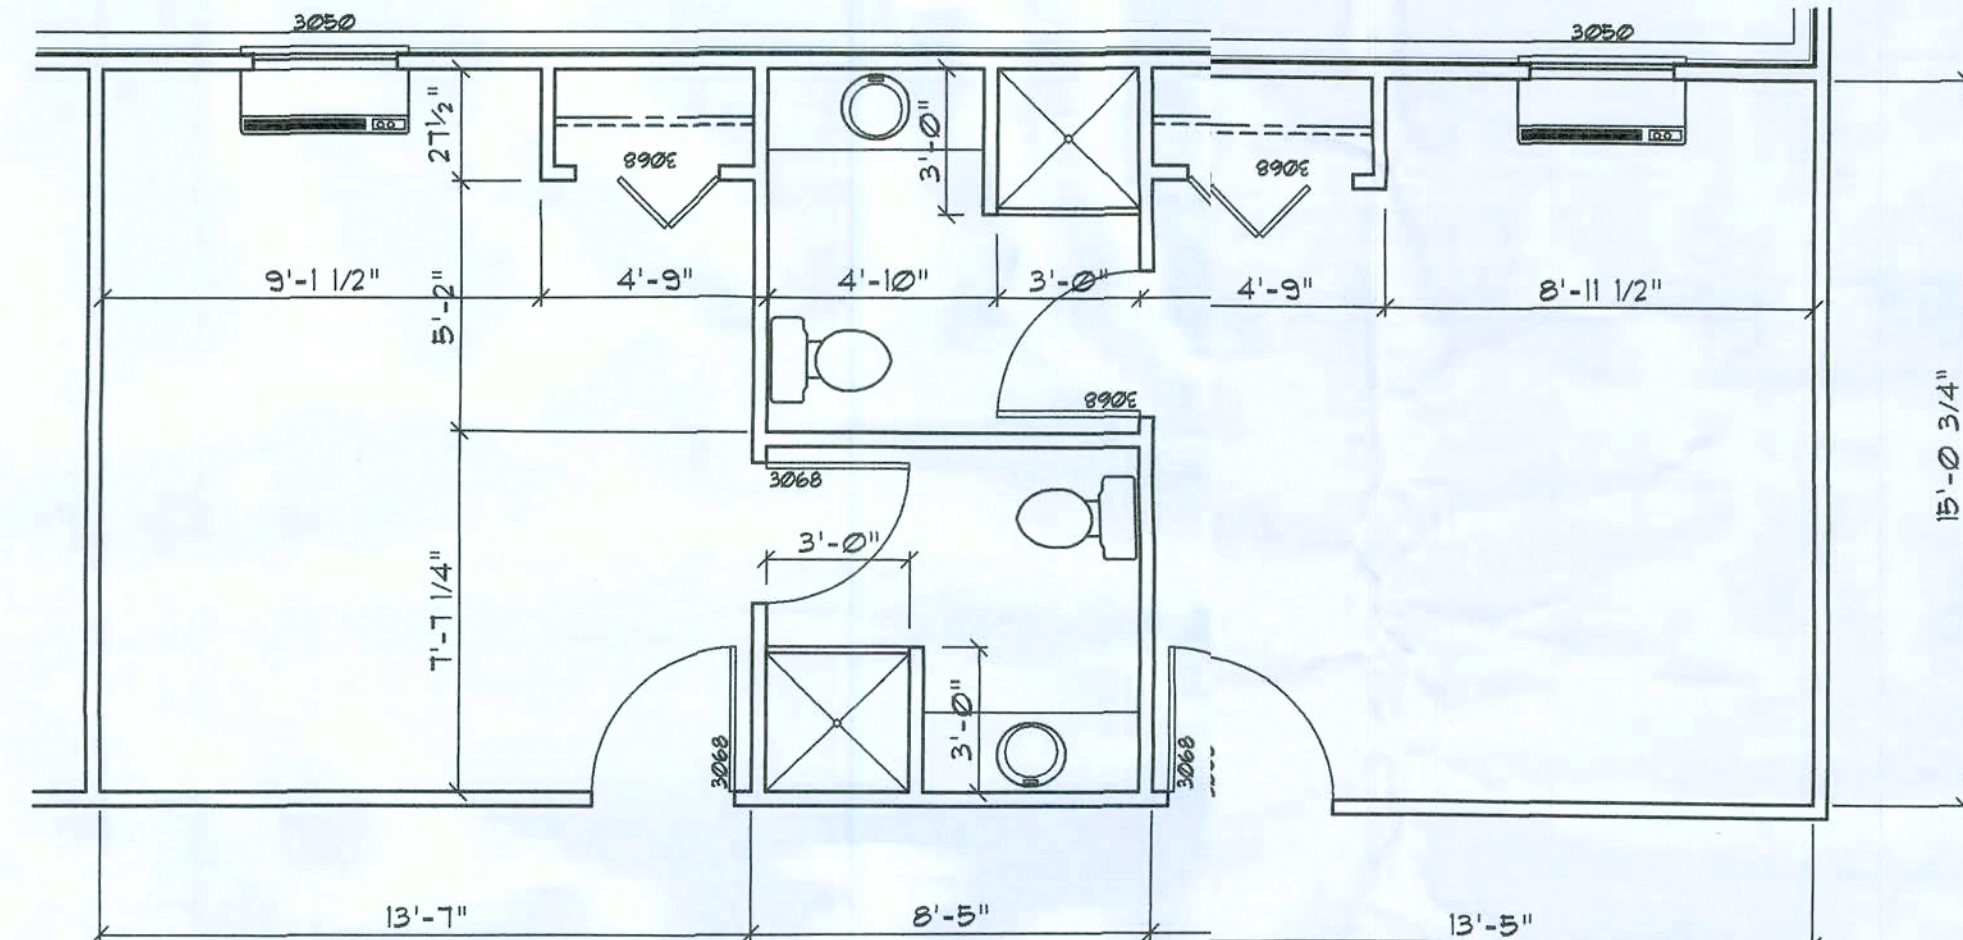


Large Dual Unit PLAN
SCALE: 1/4" = 1'-0"

EP5

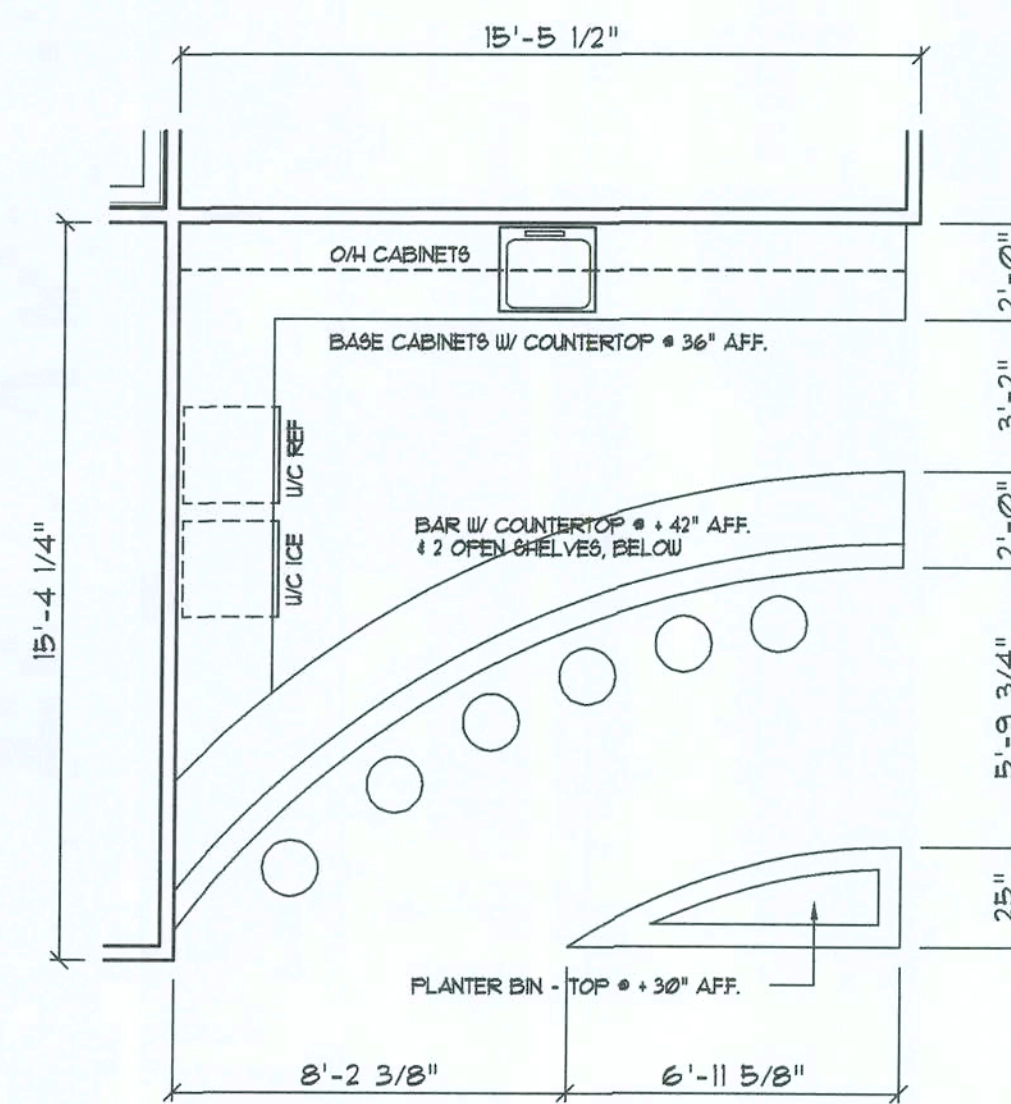

Coffee Shop PLAN
SCALE: 1/4" = 1'-0"

EP3

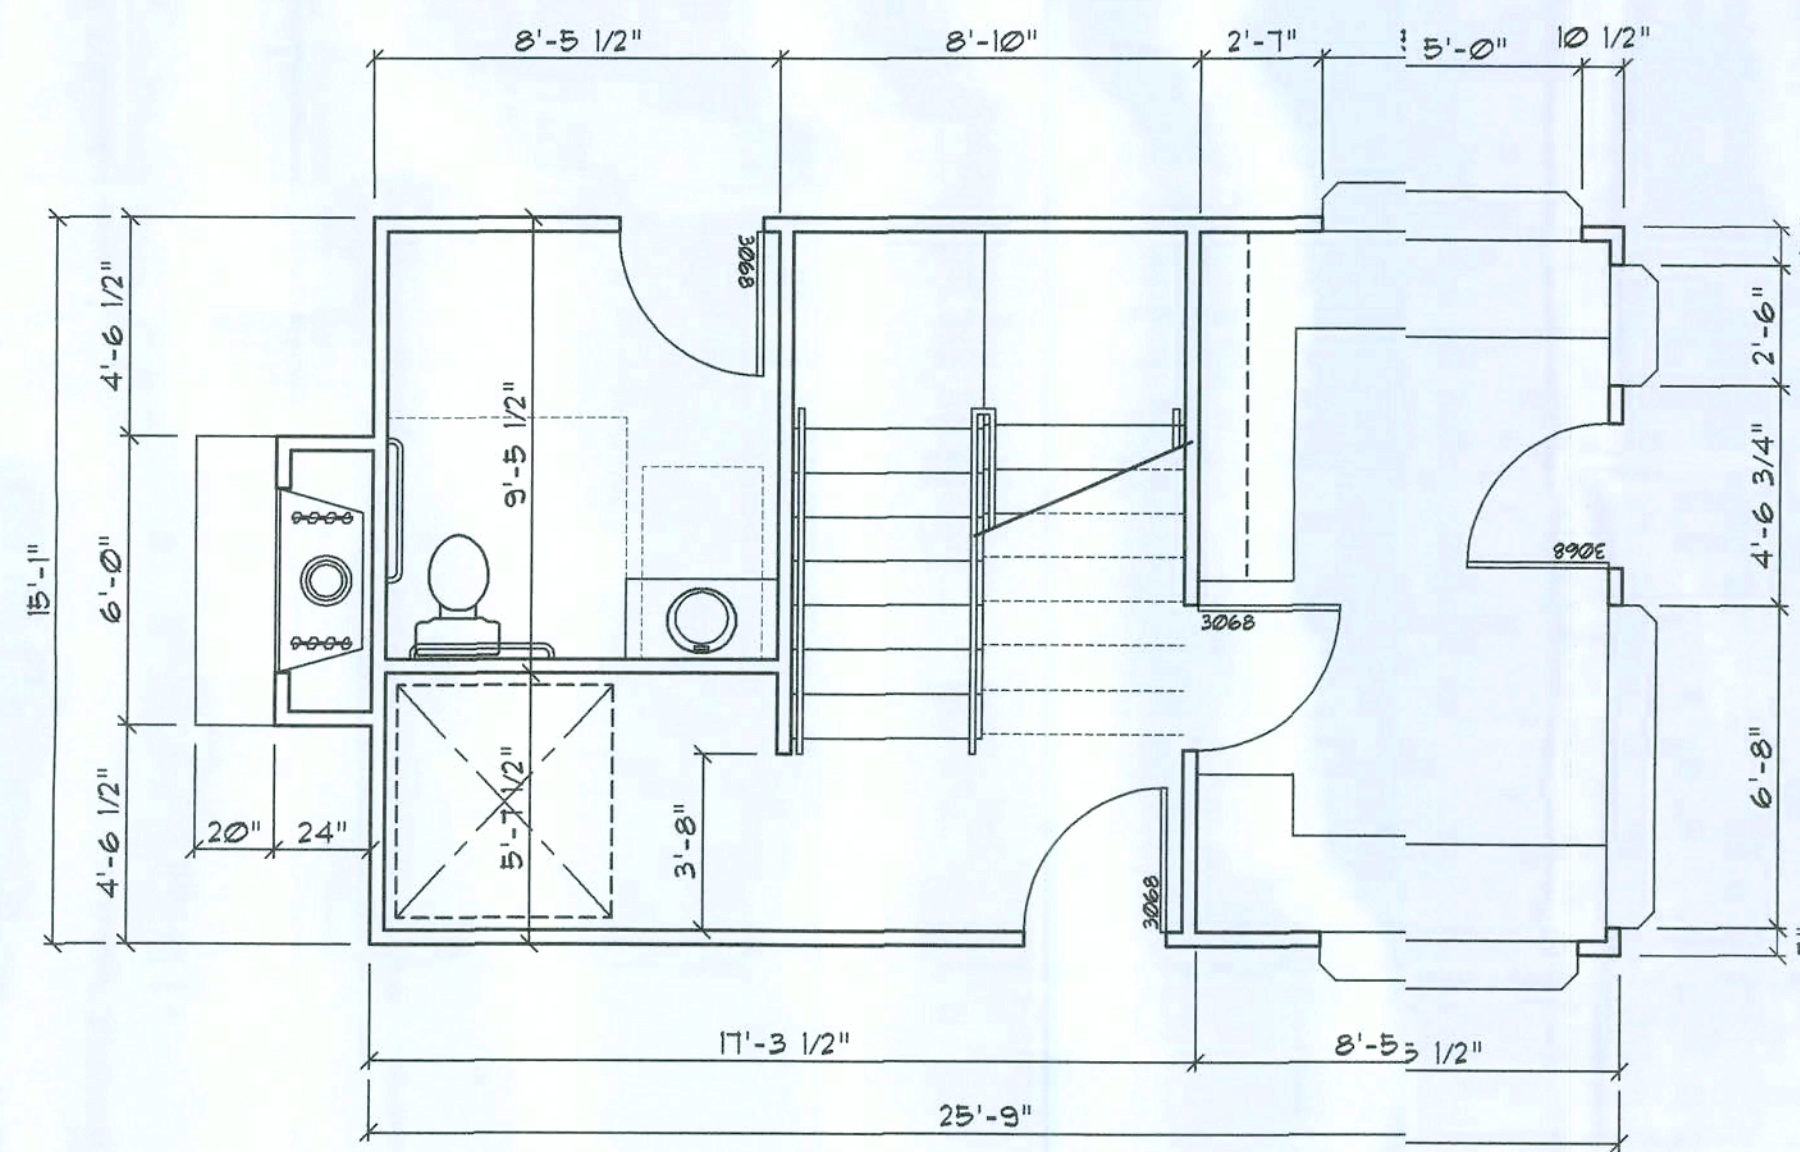

Office Area PLAN
SCALE: 1/4" = 1'-0"


EP6

APPLIANCE SPECIFICATIONS


MODELS: KR 43, KC 43, KBV 43, BRF 43T5, BCF 43B5
RD 4300A, HC 4320, HCE 45B0A,
UVFR 43, UVFC 43, GRDE 8043

FRAMING SPECIFICATIONS

NOTE: FRAMING DIMENSIONS ARE CALCULATED FOR A
NAILING FLANGE DEPTH OF 1/2"

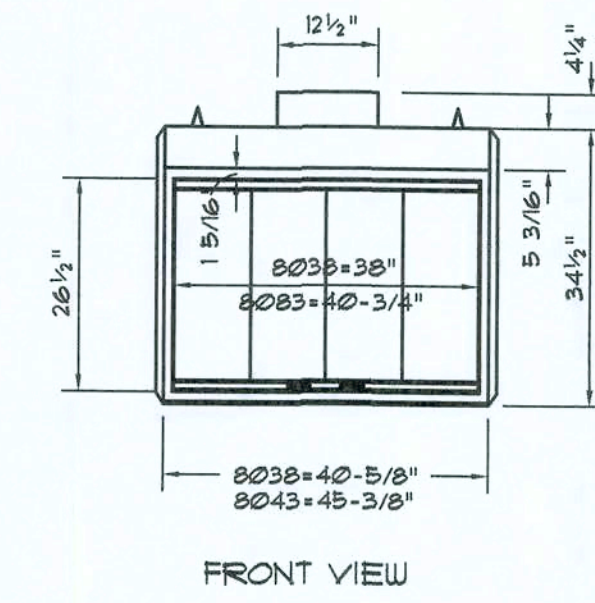


FRONT VIEW

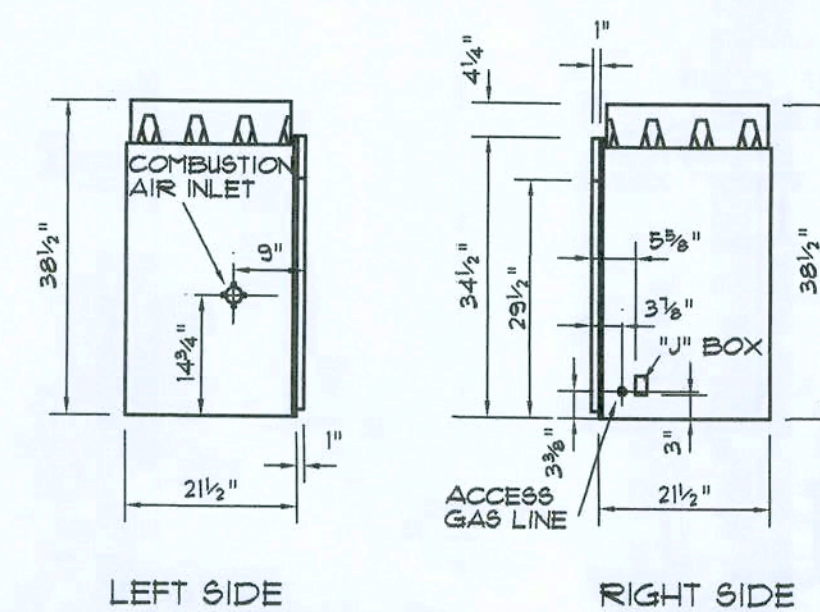


LEFT SIDE

RIGHT SIDE

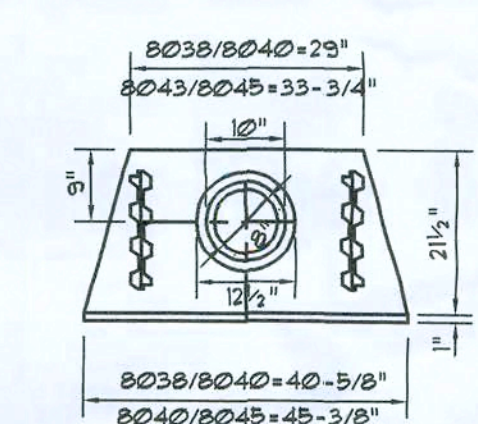

TOP VIEW

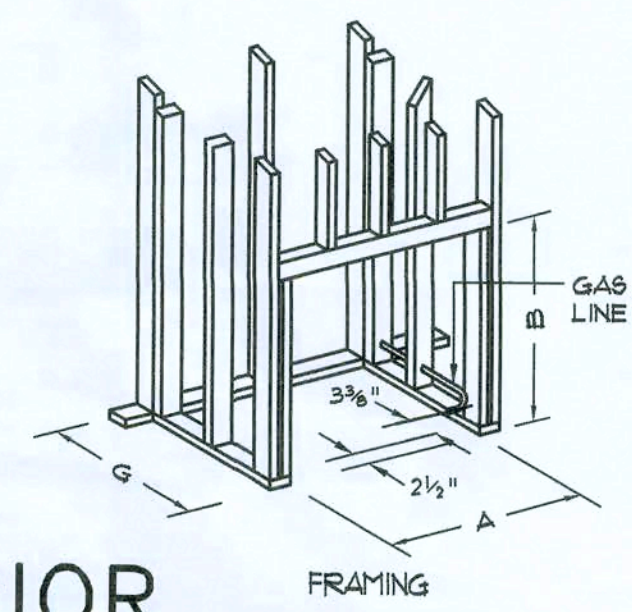


FRAMING

CORNER FRAMING DIMENSIONS	
APPLIANCE SIZES	
	38/40
A	40-3/4"
B	39"
C	29"
D	14-1/2"
E	10-3/4"
F	35-3/8"
G	21-3/8"
H	4"
J	50"

Typ. Fireplace DET.
SCALE: 1/2" = 1'-0"

EP1

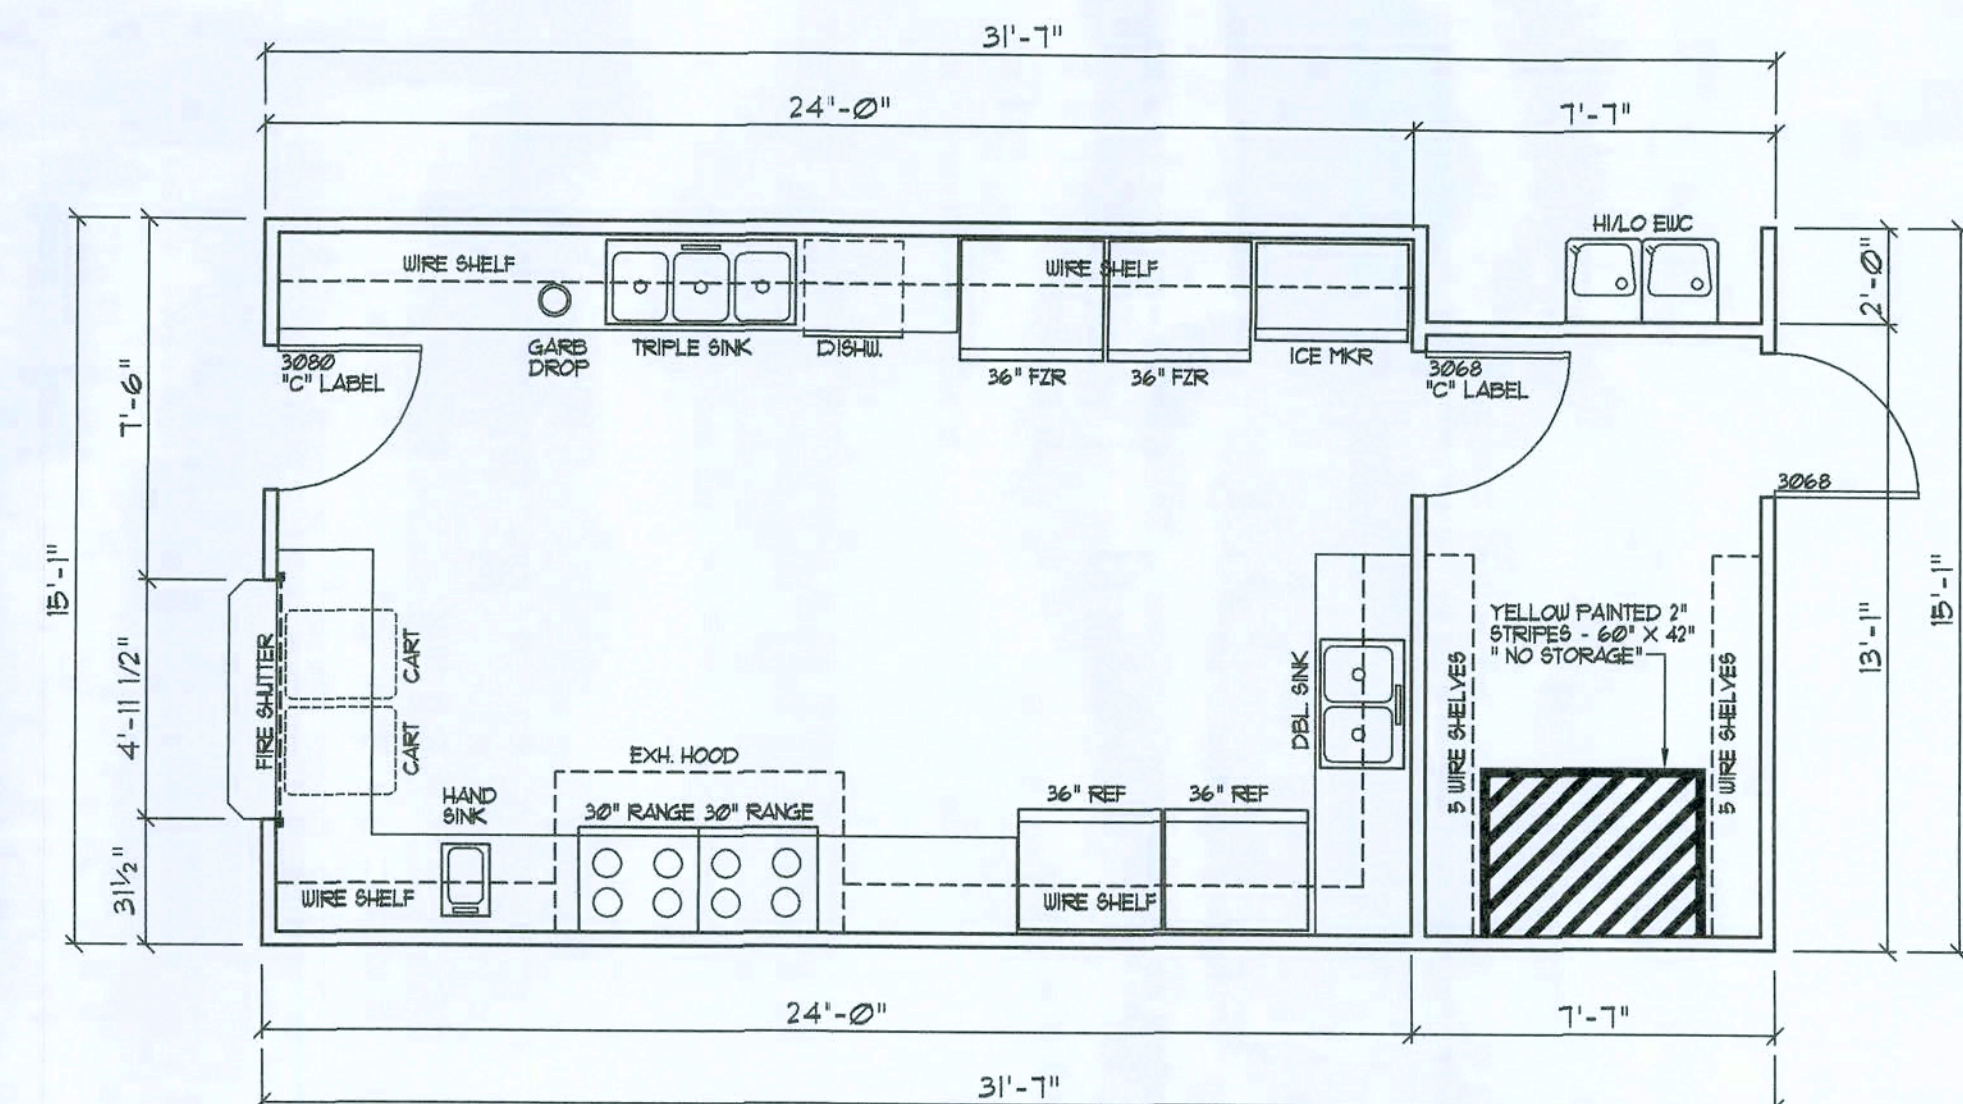

Kitchen Area PLAN
SCALE: 1/4" = 1'-0"

EP7

REVISION:
02 SEP 2020

copyright 2020
I.P. Geisler, Architect

DRAWN:
rpg

ASSISTED LIVING FACILITY FOR
GRANDE CYPRESS
LAKE CITY, COLUMBIA COUNTY, FLORIDA
ENLARGED PLANS

Calculating
1972 - 2020
N.P. Geisler, Architect
LAKE CITY, FLORIDA

NICHOLAS PAUL GEISLER ARCHITECT
N.C.A.A. Certified
1758 NW Brown Rd.
Lake City, FL 32055
386-365-4355


DATE:
16 AUG 2020
COM: K2040

SHEET:
A.7
7 OF 11

ARI007005

Digitally signed by: N. P. GEISLER
DN: cn=N. P. GEISLER, o=I.P. GEISLER, ou=ARCHITECT
Date: 2020.08.09 06:02:09 -0500


EXTERIOR WALL SHEATHING:
APPLY VERTICALLY, "Windstorm" 1/8" OSB 48" X 96", 12" OR 15"
SHEATHING. FASTEN TO THE TOP PLATE AND THE SILL PLATE WITH EITHER
6d COMMON NAILS @ 3" O.C. OR 8d COMMON NAILS @ 4" O.C. FASTEN TO
EACH STUD WITH EITHER 6d COMMON NAILS @ 6" O.C. OR 8d COMMON
NAILS @ 8" O.C.

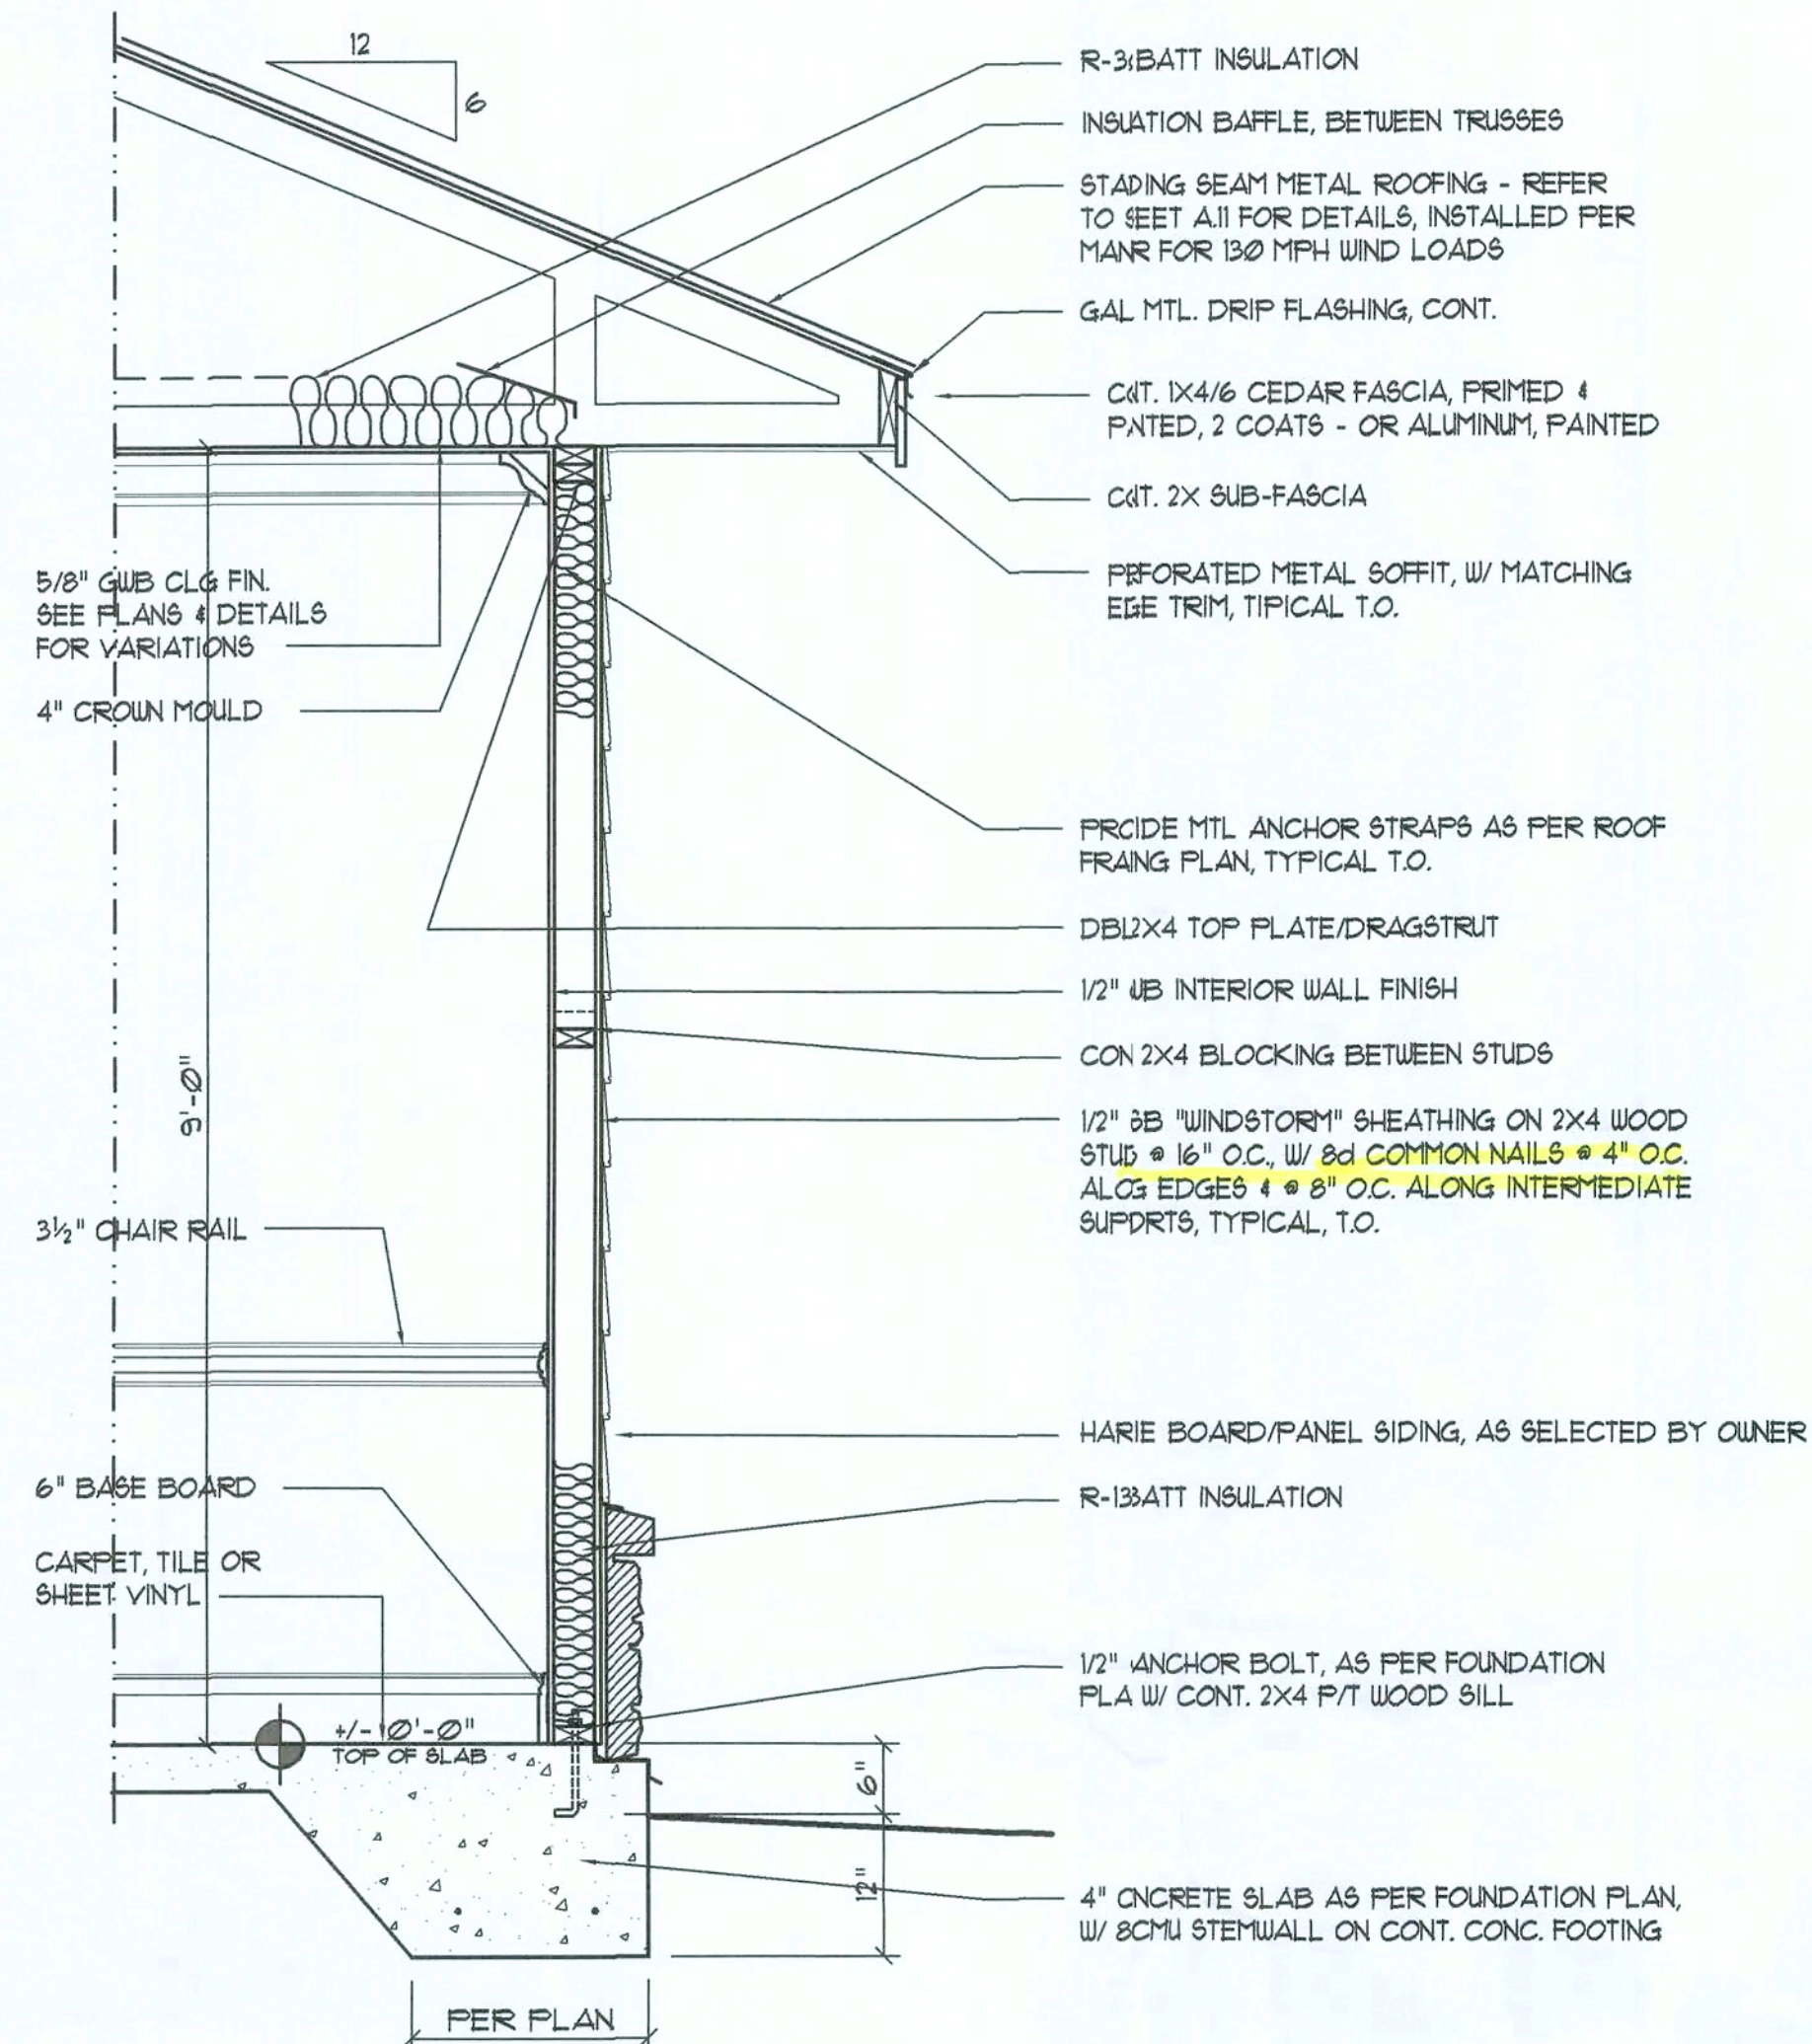

Wall SECTION

SCALE: 3/4" = 1'-0"


A

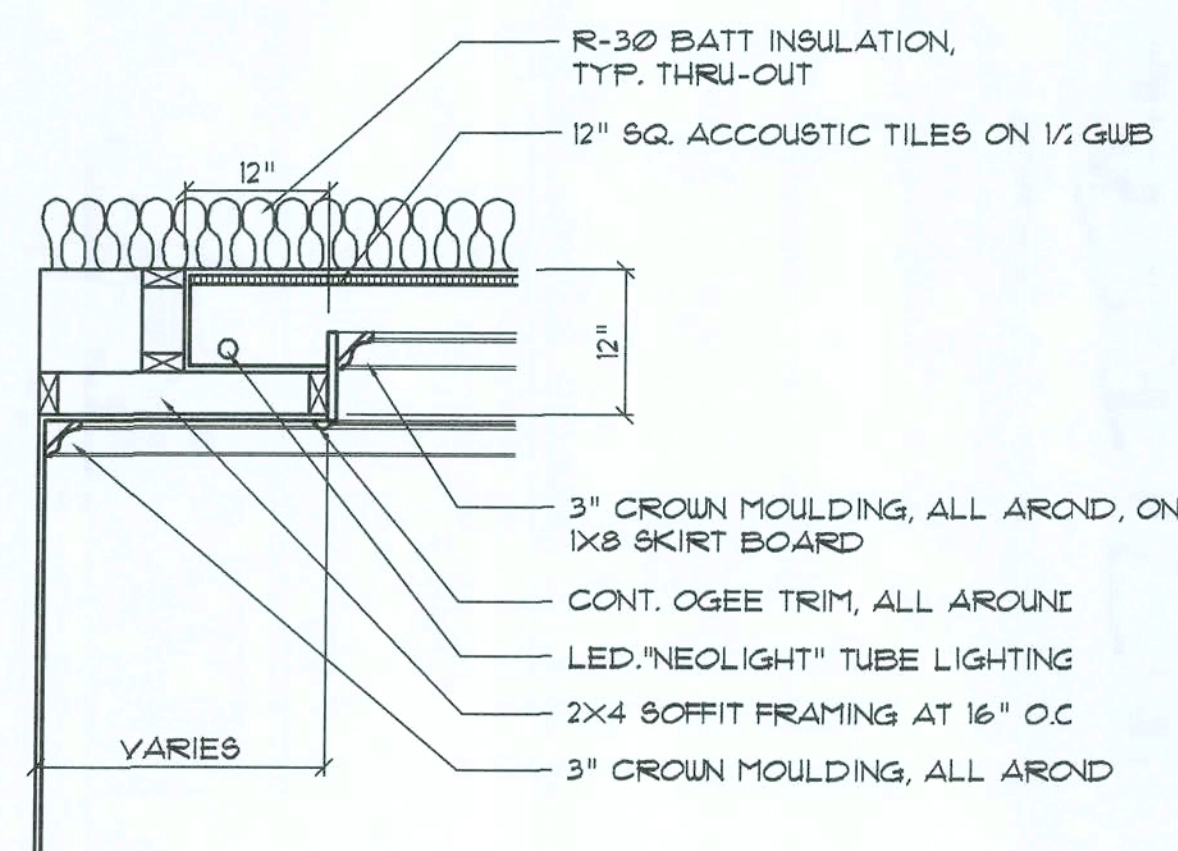

Cove Ltg./Soffit SEC.

SCALE: 3/4" = 1'-0"


C

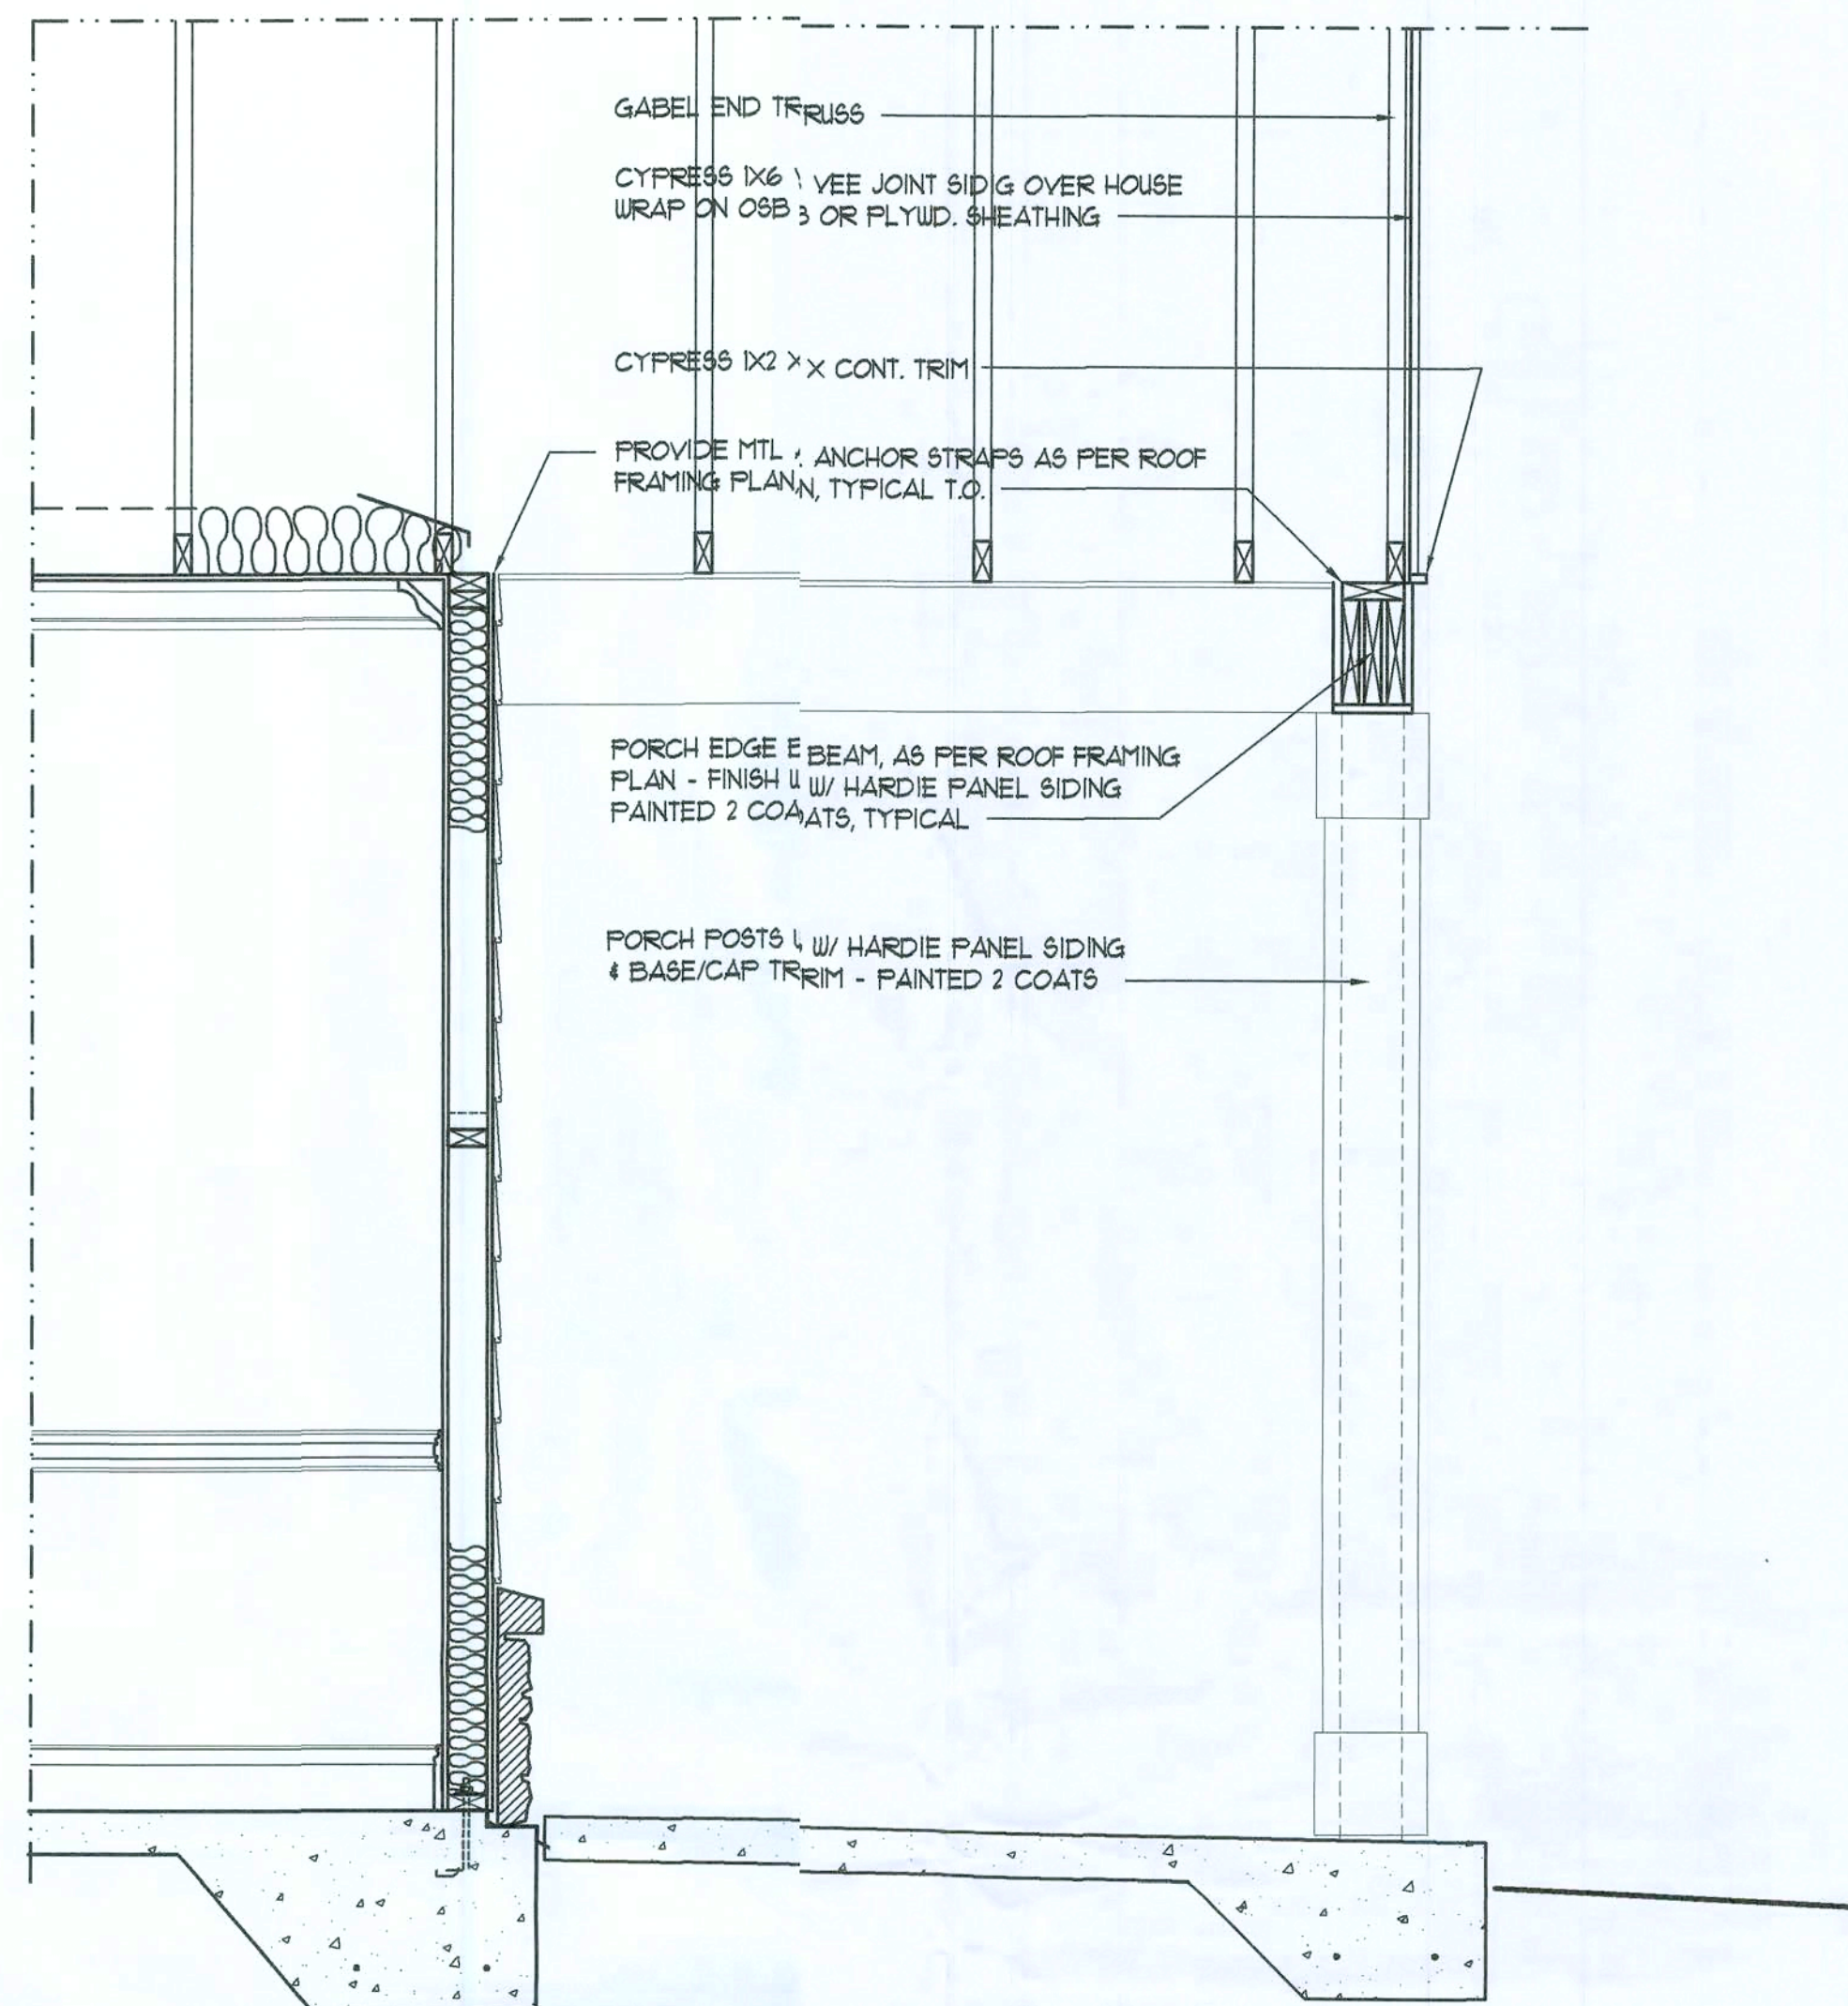

Porch Wall SECTION


SCALE: 3/4" = 1'-0"

B

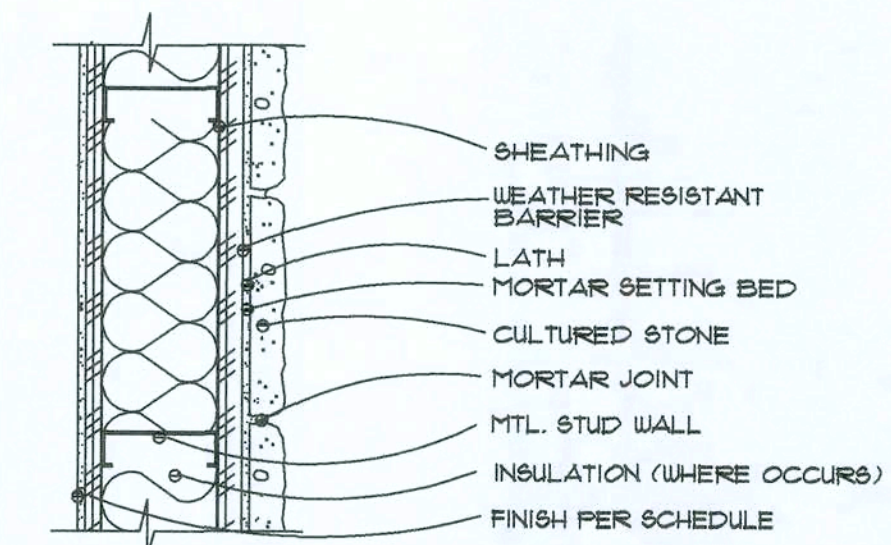

INSTALLATION OVER SHEATHING


SCALE: NONE

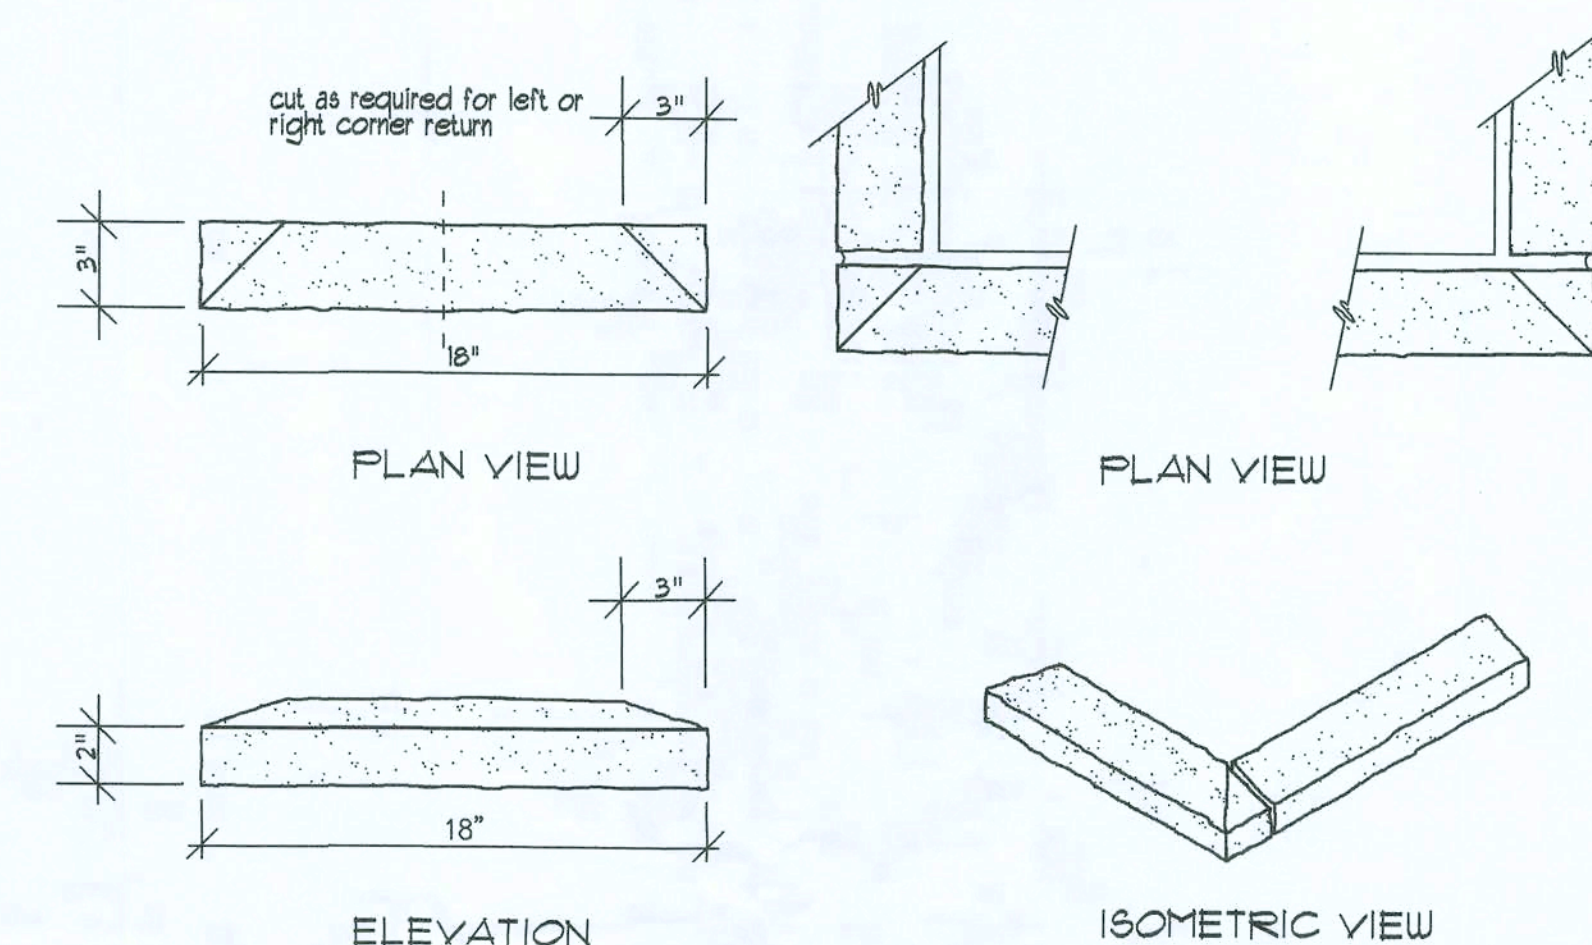

OUTSIDE CORNER

WATERTABLE outside corner components

SCALE: NONE

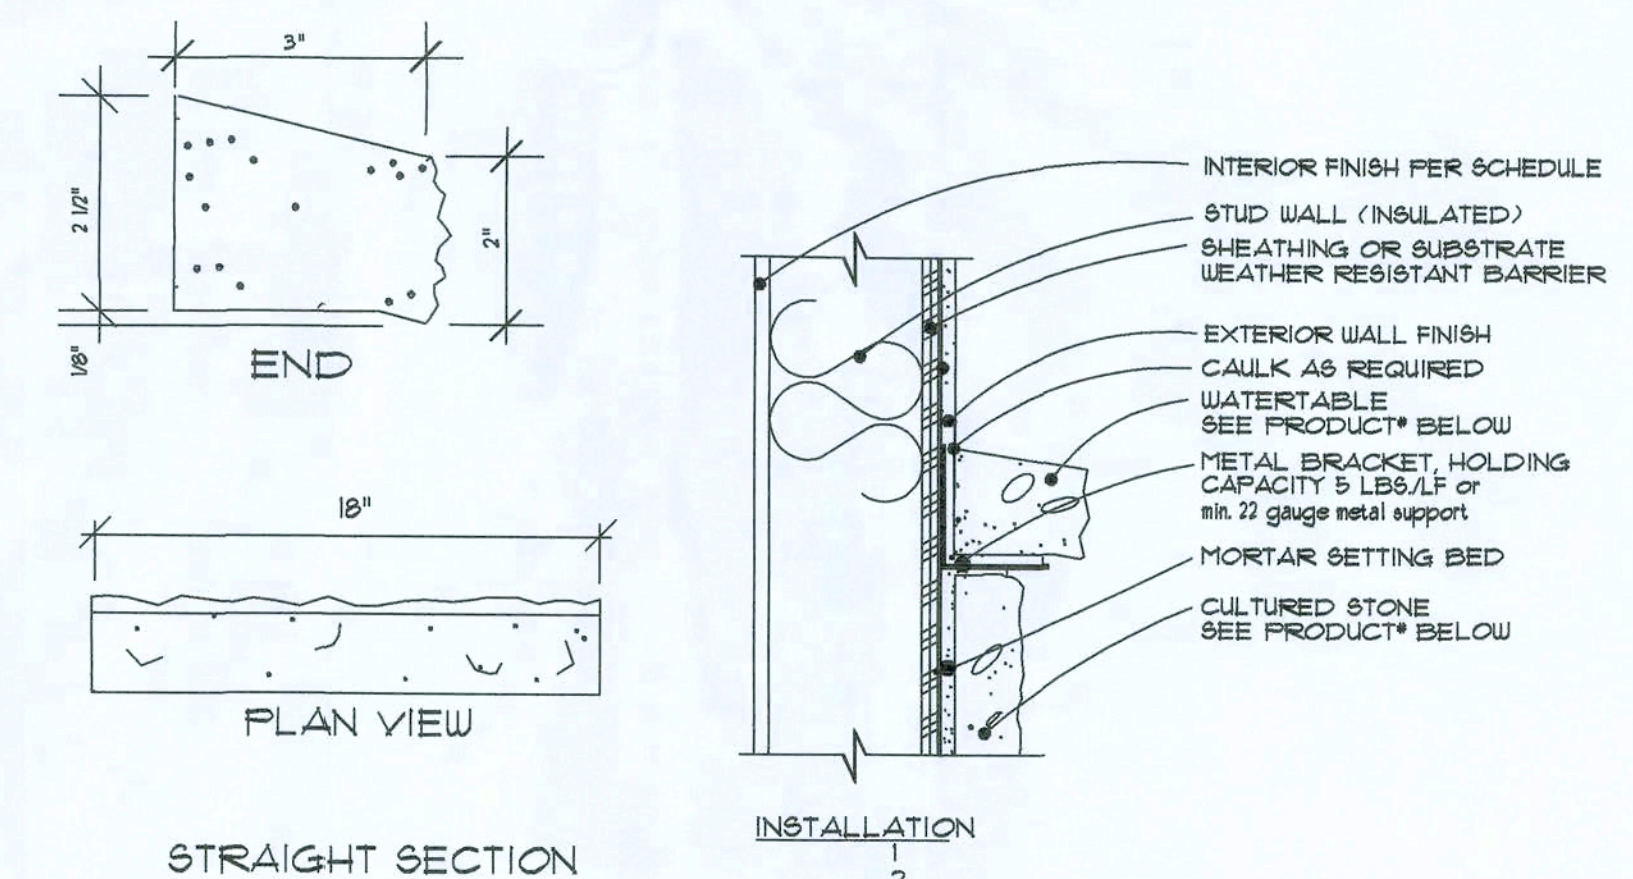

WATERTABLE @ WAINSCOT

SCALE: NONE

CULTURED STONE DETAILS

SCALE: NONE

III

Digitally signed by: N.P. GIESLER
DN: cn = N.P. GIESLER, c = US
Date: 2020.08.09 09:02:49 -0500

REVISION:
01 SEP 2020

Copyright 2020
N.P. Giesler, Architect

DRAWN:

np8

ASSISTED LIVING FACILITY for
GRANDE CYPRESS
LAKE CITY, COLUMBIA COUNTY, FLORIDA
WALL SECTIONS & DETAILS

Celebrating
48 Years of Service
1972-2020
N.P. Giesler, Architect
AR0007005

NICHOLAS
GIESLER
ARCHITECT
N.C.A.R.B. Certified


DATE
18 AUG 2020
COMB:
2K2040

SHEET:
A.8
8 OF 11

AR0007005


APR 00 7 003

FIELD "AS-BUILT" NOTE:

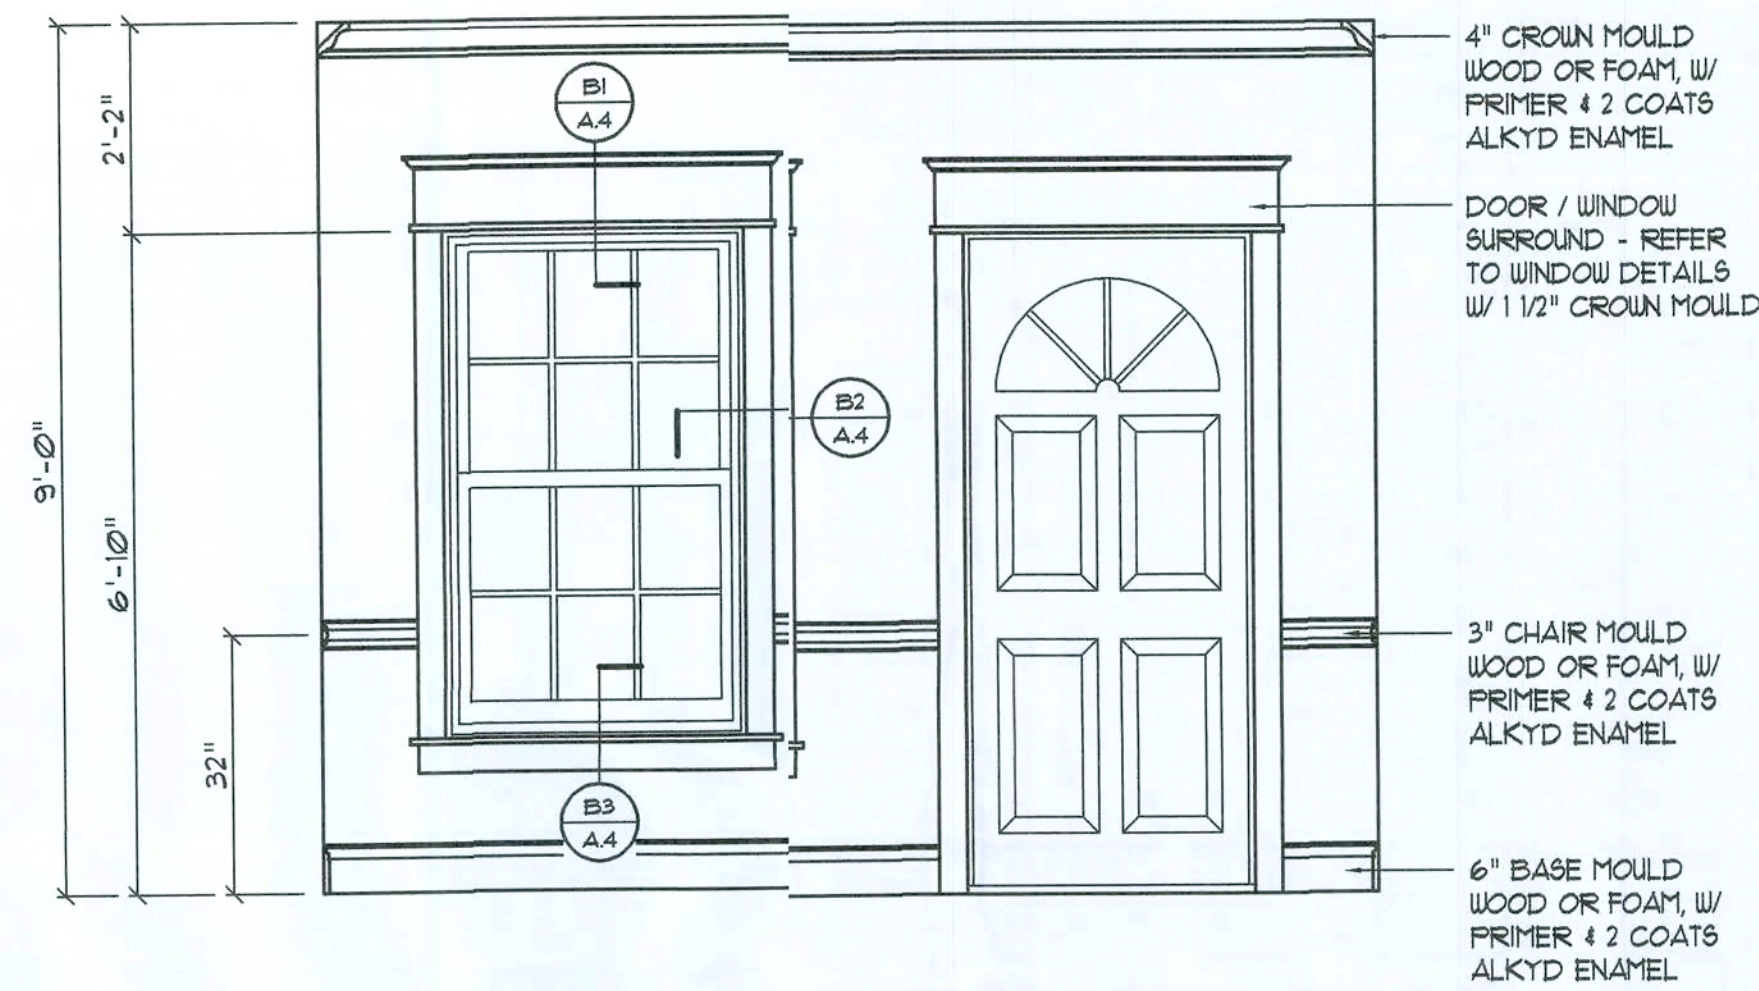


Int. Wall Trim DETAIL


SCALE: 1/2" = 1'-0"

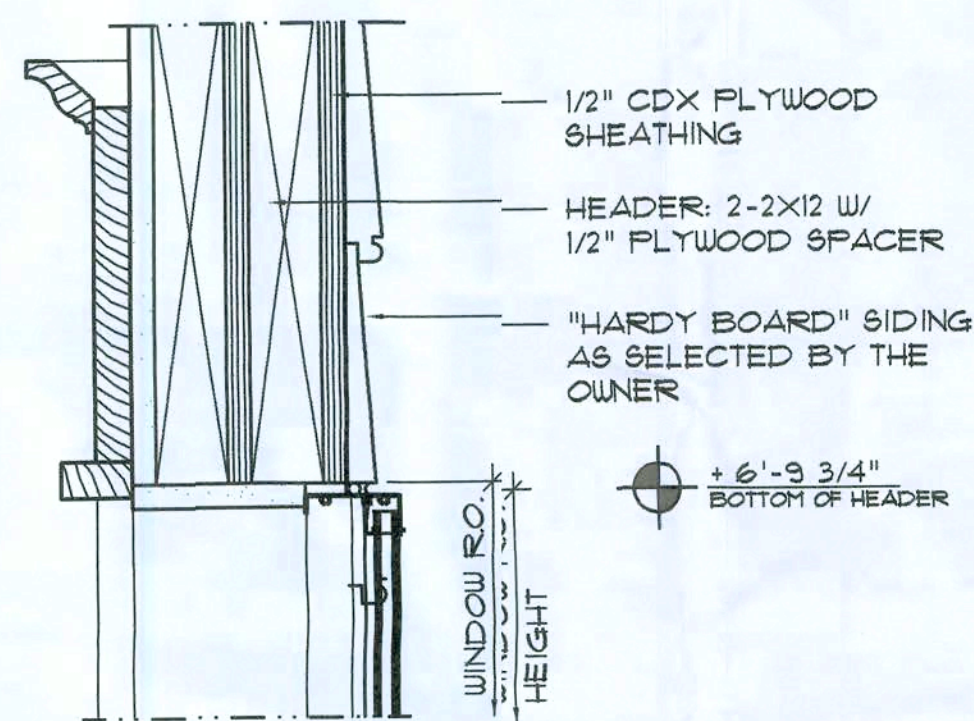

HEAD DETAIL WOOD SASH

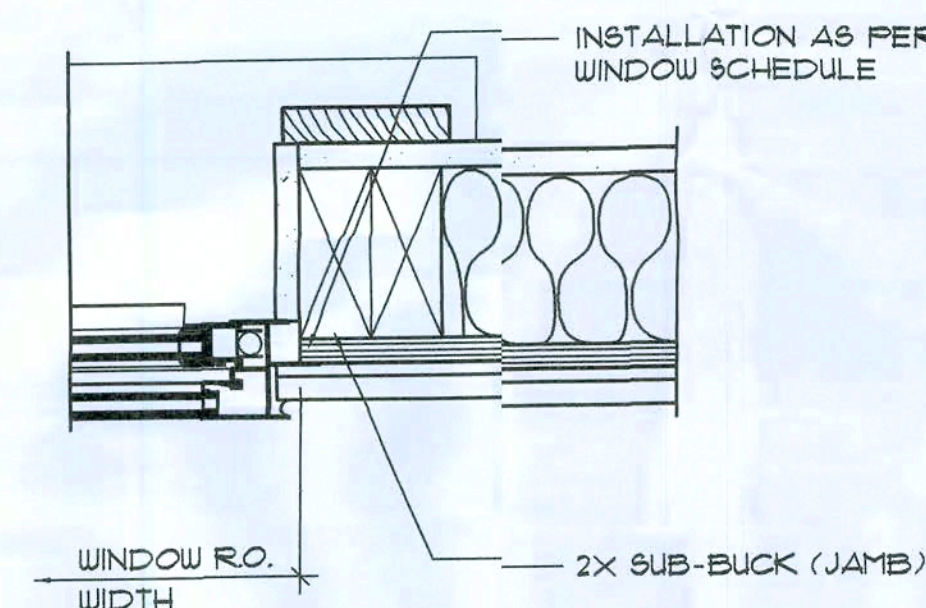

JAMB DETAIL WOOD SASH

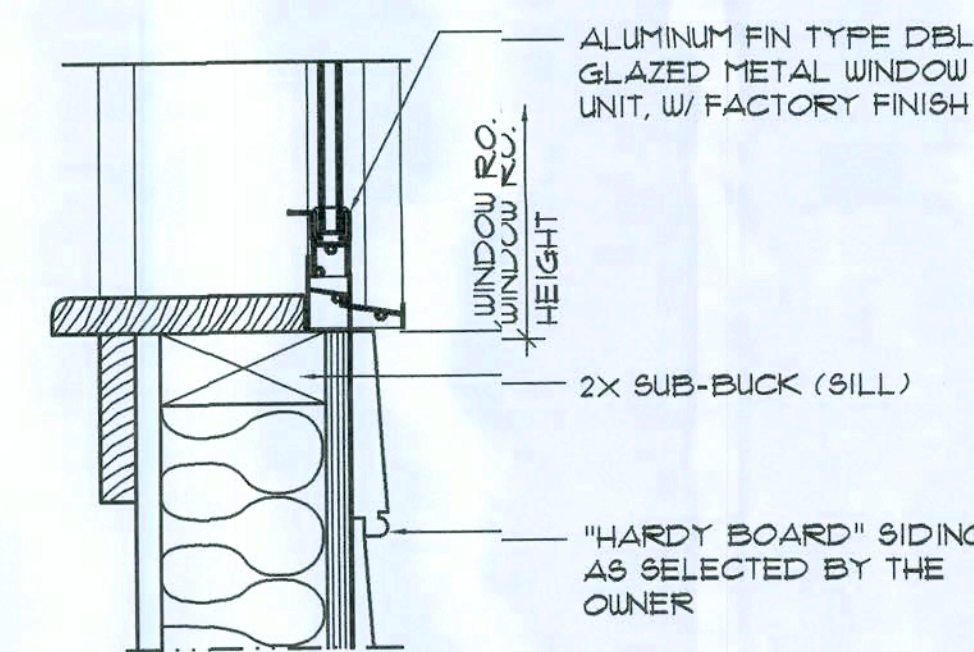


SILL DETAIL WOOD SASH

Typical Window DET'S

SCALE: 3" = 1'-0"


STOREFRONT GLASS & GLAZING:

1. REFER TO PLANS, AND DETAILS AND FOR SIZE, AND TYPE.
2. MATERIALS: ALL GLASS AND GLAZING SHALL BE IN ACCORDANCE WITH THE STANDARDS AND RECOMMENDATIONS OF THE CURRENT EDITION OF THE GLAZING MANUAL OF THE FLAT GLASS JOBBERS ASSOCIATION.
3. EXTERIOR GLASS SHALL BE 1/2" CLEAR FULLY TEMPERED WITH BUTT GLAZED JOINTS, JOINT NOT TO EXCEED 3/8" GAP NOR LESS THAN 1/4". SEAL JOINTS WITH COMMERCIAL GRADE NEUTRAL CURE, CLEAR SILICONE. ACID CURE SILICONE WILL NOT BE ACCEPTED. APPLICATION SHALL BE TAPE AND TOOL.
4. MIRRORS SHALL BE "A" QUALITY 1/4" THICK POLISHED PLATE WITH FULL STAINLESS OR ALUMINUM FRAME AND CONCEALED FASTENERS.
5. STOREFRONT SHALL BE EQUAL TO YKK AP AMERICA, INC. 7606 CURRENCY DR. ORLANDO, FL 32807, OTHER APPROVED MFGRS ARE KALNEER CO. AND VISTAWALL ARCHITECTURAL.
6. ALL ALUMINUM STOREFRONT FRAMING AND DETAILS INDICATED ON THE DRAWINGS AND/OR DETAILS, SHALL BE EQUAL TO VISTAWALL SERIES 2000. THE FRAMING SHALL BE ACCURATELY ASSEMBLED WITH UNEXPOSED FASTENERS UTILIZING EXTRUDED SPINES, CLIPS AND/OR SNAP-IN FEATURES. ALL GLAZING SHALL BE HELD IN PLACE BY EPDM GLAZING GASKETS. NO APPLIED STOPS SHALL BE PERMITTED. ALL EXPOSED SURFACES SHALL BE FREE OF UNSIGHTLY SCRATCHES AND BLEMISHES. THE FINISH SHALL BE ANODIZED ALUMINUM. COLOR: DK. BRONZE IN ACCORDANCE W/ AA-M222A42/A44.
7. FINISH OF ALL SILL FLASHING SHALL BE 240" ALUMINUM TO MATCH STOREFRONT MATERIAL.
8. DOOR FRAMES FOR ENTRANCE DOORS SHALL BE ALUMINUM STOREFRONT FRAME WITH CUT CUTS AND BACKING PLATES FOR (3) BUTT HINGES FOR EACH DOOR LEAF. LOCATION OF HINGES TO BE COORDINATED BY GENERAL CONTRACTOR WITH STOREFRONT SUBCONTRACTOR.
9. ALL DOOR AND FRAMING SECTIONS SHALL BE EXTRUDED ALUMINUM ALLOY AND TEMPERED TO MEET OR EXCEED FINISHING AND STRUCTURAL CRITERIA. DOOR STILES AND RAILS, EXCLUDING GLASS STOPS, SHALL BE TUBULAR AND HAVE 0.025" WALL THICKNESS. ALL WEATHERING SHALL BE HARDBACKED SILICONE TREATED POLYPROPYLENE. ANY EXPOSED FASTENERS SHALL BE ALUMINUM, STAINLESS STEEL OR OTHER NON-CORROSIVE MATERIAL. DOOR VERTICAL STILES SHALL BE NOMINAL 4-1/4" BE A MINIMUM OF 8-1/2". ALL DIMENSIONS NOTED ABOVE ARE WITH GLASS STOPS ON.
10. ALL EXPOSED SURFACES SHALL BE FREE OF UNSIGHTLY SCRATCHES AND BLEMISHES. THE FINISH SHALL BE ANODIZED, AS PER VISTAWALL ARCHITECTURAL PRODUCTS STANDARD.
11. DOOR STILES AND RAILS SHALL BE ACCURATELY JOINED AT CORNERS WITH CONCEALED REINFORCEMENT BRACKETS SECURED WITH BOLTS AND SCREWS, AND SHALL BE "MIG" WELDED. DOORS SHALL HAVE SNAP-IN STOPS WITH BULB GLAZING VINYL ON BOTH SIDES OF GLASS. NO EXPOSED SCREWS SHALL BE PERMITTED. EACH DOOR LEAF SHALL BE EQUIPPED WITH AN ADJUSTING MECHANISM LOCATED IN THE TOP RAIL NEAR THE LOCK STILE, WHICH PROVIDES FOR MINOR CLEARANCE ADJUSTMENTS AFTER INSTALLATION. WEATHERING SHALL BE INSTALLED IN THE HINGE STILE OF PAIR OF DOORS. DOOR FRAME AND SIDELIGHT FRAMING SHALL BE ACCURATELY JOINED AT CORNERS WITH CONCEALED SCREWS.
12. DESIGN CRITERIA FOR WIND LOADS SHALL BE IN ACCORDANCE WITH ASCE-7-10 DESIGN WITH WIND VELOCITY OF 130 MPH, BUILDING IMPORTANCE FACTOR OF 1.0.
13. ALL HARDWARE FOR ENTRANCE DOORS, WITH THE EXCEPTION OF THE CYLINDERS, SHALL BE FURNISHED AND INSTALLED BY ALUMINUM STOREFRONT CONTRACTOR AS FOLLOWS:
 - A. 1-1/2" PAIR OF 4-1/2" BUTTS
 - B. ADAMS-RITE 8400 SERIES MORTISE EXIT DEVICE
 - C. LCN SUPER SMOOTH MOUNTED PARALLEL ARM WITH DROP PLATE
 - D. BUG BEEP WITH SLIDE ON COVER
 - E. MANUFACTURER'S STANDARD WEATHERSTRIPPING
 - F. FH - II FULL HANDLE ON EXTERIOR
 - G. ALL HARDWARE SHALL BE FINISHED AS SELECTED BY THE OWNER.
14. ALL ITEMS SHALL BE SET IN THEIR CORRECT LOCATIONS AS SHOWN ON THE DRAWINGS AND SHALL BE LEVEL, SQUARE, PLUMB, AND AT PROPER ELEVATION AND IN ALIGNMENT WITH OTHER WORK. THIS CONTRACTOR SHALL DO ALL CAULKING AND SEALING ASSOCIATED WITH THIS WORK.
15. SEAL ALL JOINTS. FRAMING MEMBERS SHALL BE SCREWED IN PLACE USING BACKING, ANCHOR PLUGS, OR STRAPS AS REQUIRED. WHERE MOLDINGS ARE JOINED, THEY SHALL BE ACCURATELY CUT AND FITTED TO RESULT IN A TIGHTLY CLOSED HAIRLINE JOINT. NO UNFINISHED ALUMINUM SHALL BE VISIBLE.
16. DOORS SHALL OPERATE FREELY AND SHALL NOT RATTLE WHEN CLOSED. SLING TYPE DOORS SHALL HAVE HEAD AND JAMB CLEARANCE OF 3/32" PLUS OR MINUS 1/32".
17. AFTER ERECTION, THE CONTRACTOR SHALL PROTECT EXPOSED PORTIONS FROM DAMAGE BY MACHINES, FLASTER, LIME, PAINT, ACID, CEMENT, OR OTHER HARMFUL COMPOUNDS. THE CONTRACTOR SHALL BE RESPONSIBLE FOR REMOVAL OF PROTECTIVE MATERIALS AND CLEANING PER STOREFRONT FRAMING MANUFACTURER'S PRINTED INSTRUCTIONS.

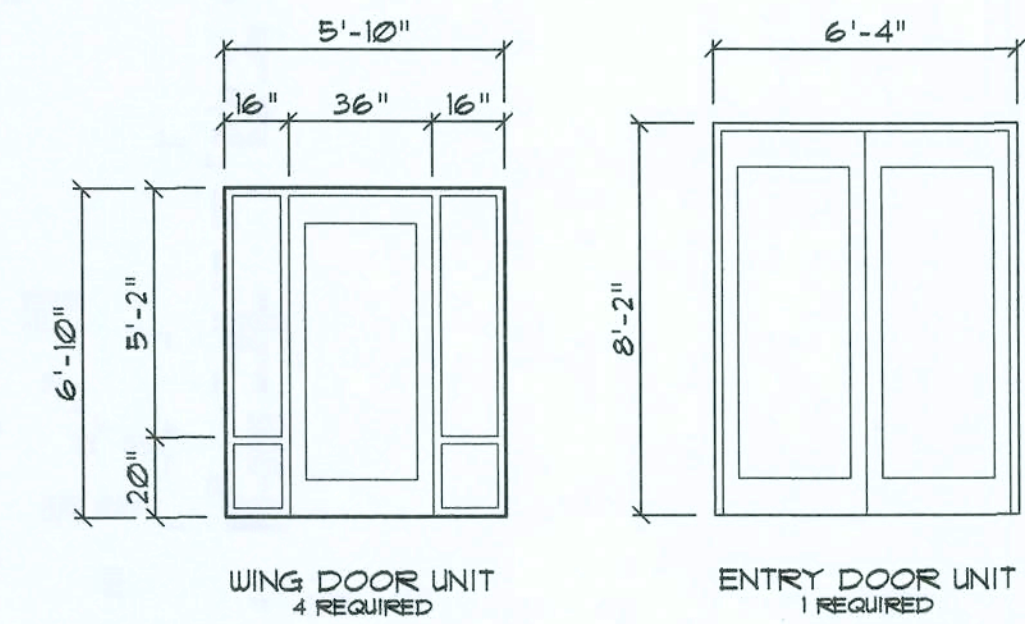


TEMPERED GLASS NOTES:

- THE FOLLOWING SHALL BE CONSIDERED SPECIFIC HAZARDOUS LOCATIONS FOR THE PURPOSES OF GLAZING:
1. GLAZING IN SLIDING DOORS AND FIXED AND SLIDING PANELS OF SLIDING (PATIO) DOOR ASSEMBLIES.
 2. GLAZING IN AN INDIVIDUAL FIXED OR OPERABLE PANEL ADJACENT TO A DOOR WHERE THE NEAREST VERTICAL EDGE IS WITHIN A 24-INCH (610 MM) RADIUS OF THE DOOR IN A CLOSED POSITION AND WHERE BOTTOM EDGE IS LESS THAN 60 INCHES (1524 MM) ABOVE THE FLOOR OR WALKING SURFACE. EXCEPTION: GLAZING IN WALLS PERPENDICULAR TO THE PLANE OF THE DOOR IN A CLOSED POSITION IN GROUP R3 OR WITHIN DUELLING UNITS IN GROUP R3 SHALL BE SUBJECT TO 2004 IBC 2406.2.4.1.
 3. GLAZING IN AN INDIVIDUAL FIXED OR OPERABLE PANEL, OTHER THAN THOSE LOCATIONS DESCRIBED IN ITEMS 2 ABOVE, THAT MEETS ALL OF THE FOLLOWING CONDITIONS:
 - 3.1 EXPOSED AREA OF AN INDIVIDUAL PANE GREATER THAN 9 SQ FT (834 172).
 - 3.2 BOTTOM EDGE LESS THAN 18 INCHES (457 MM) ABOVE THE FLOOR.
 - 3.3 TOP EDGE GREATER THAN 36 INCHES (914 MM) ABOVE THE FLOOR.
 - 3.4 ONE OR MORE WALKING SURFACES WITHIN 36 INCHES (914 MM) HORIZONTALLY OF THE PLANE OF THE GLAZING.

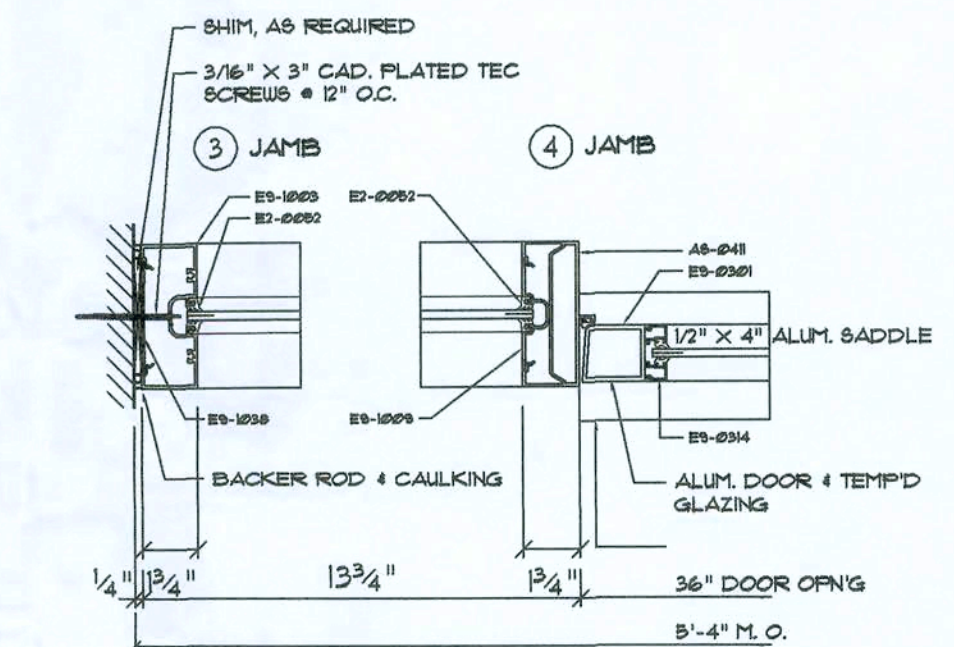

Typical Horizontal SEC.

SCALE: 2" = 1'-0"

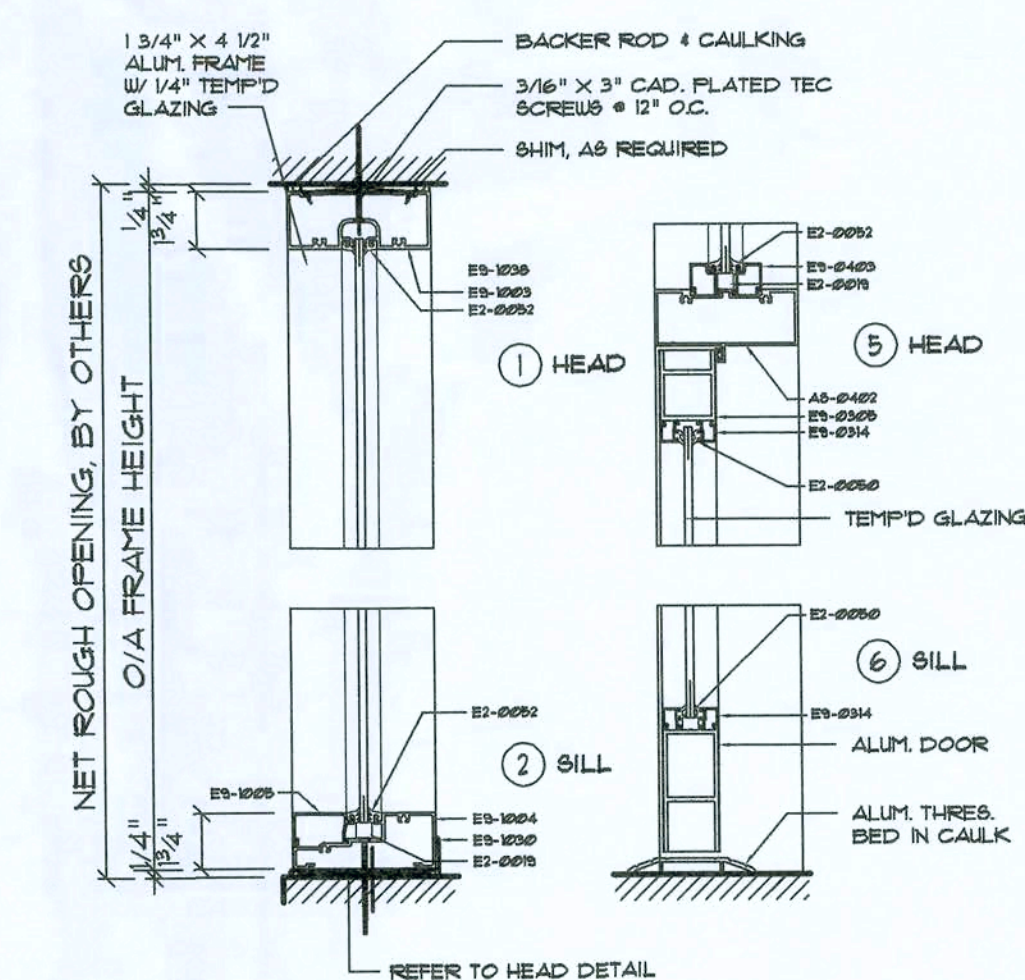

Typical Vertical SEC.

SCALE: 2" = 1'-0"

Storefront Door DET'S

SCALE: VARIOUS FIELD MEASUREMENTS:
FIELD VERIFY ALL OVERALL FRAME
SIZES PRIOR TO METALS FABRICATION

Digitally signed by N. P. GEISLER
DN: cn = N. P. GEISLER, o = ARCHITECT
Date: 2020.08.09 16:04:05 -0500

REVISION:
02 SEP 2020

Copyright, 2020
N.P. Geisler, Architect

DRAWN:
178

ASSOCIATED LIVING FACILITY for
GRANDE CYPRESS
LAKE CITY, COLUMBIA COUNTY, FLORIDA
WINDOW-STOREFRONT DETAILS

1756 NW Broward Rd.,
N.P. Geisler, Architect
386-365-4355
N.C.A.R.B. Certified

**NICHOLAS
GEISLER
ARCHITECT**
N.C.A.R.B. Certified

DATE:
18 AUG 2020

CHN:

2K2040


SHEET:

A.10

10 OF 11


A30007005

These drawings, as instruments of service, are the sole property of the architect, and may not be used, copied or reproduced in whole or in part, for use on or incorporated within any other job without specific and individual authorization by the architect.

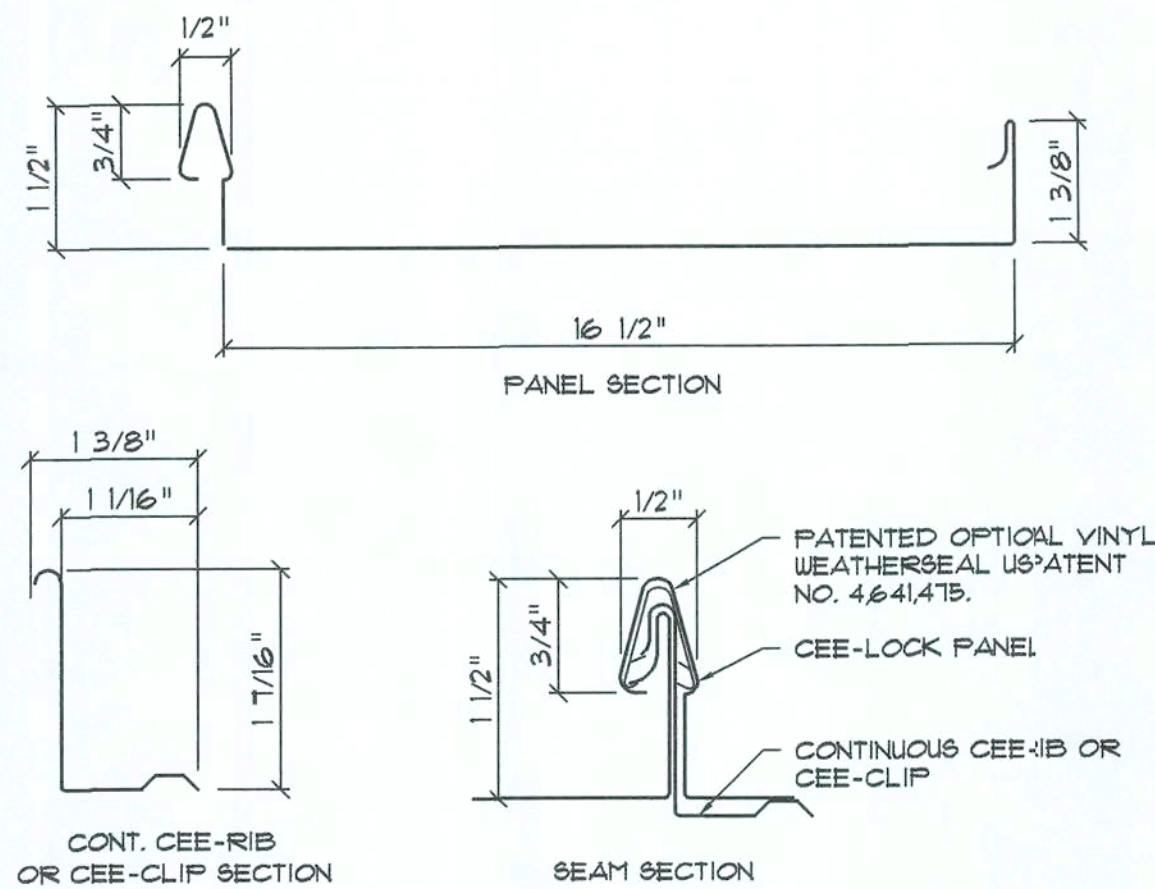


PANEL DETAIL

SCALE: NONE

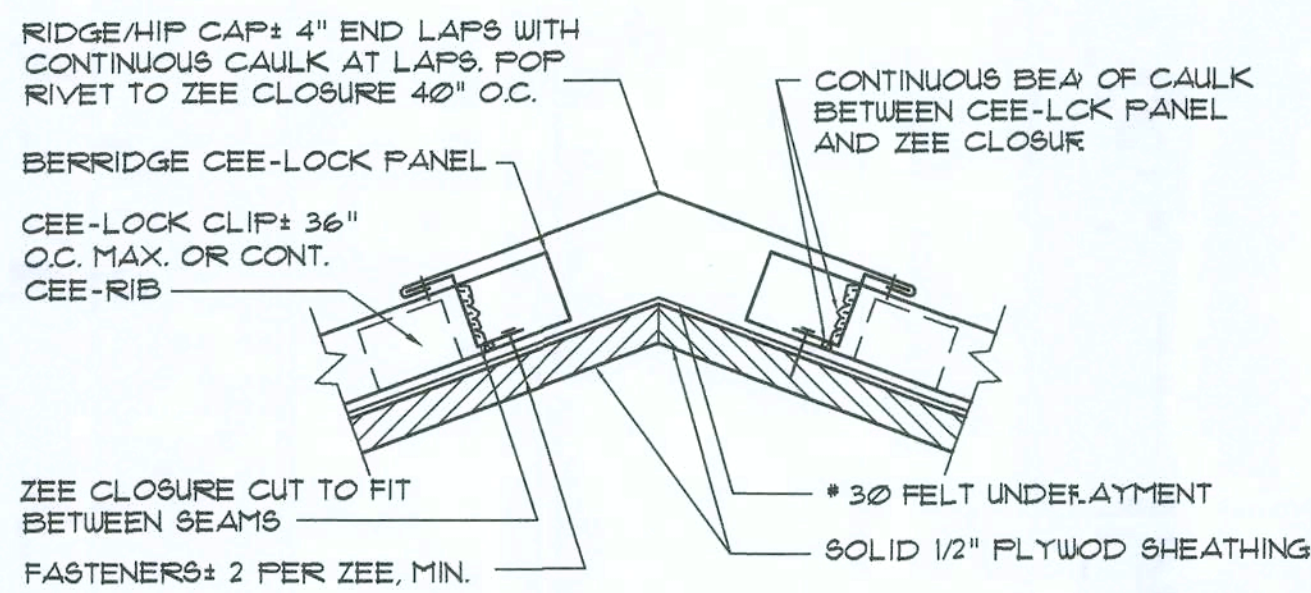


RIDGE/HIP DETAIL

SCALE: NONE

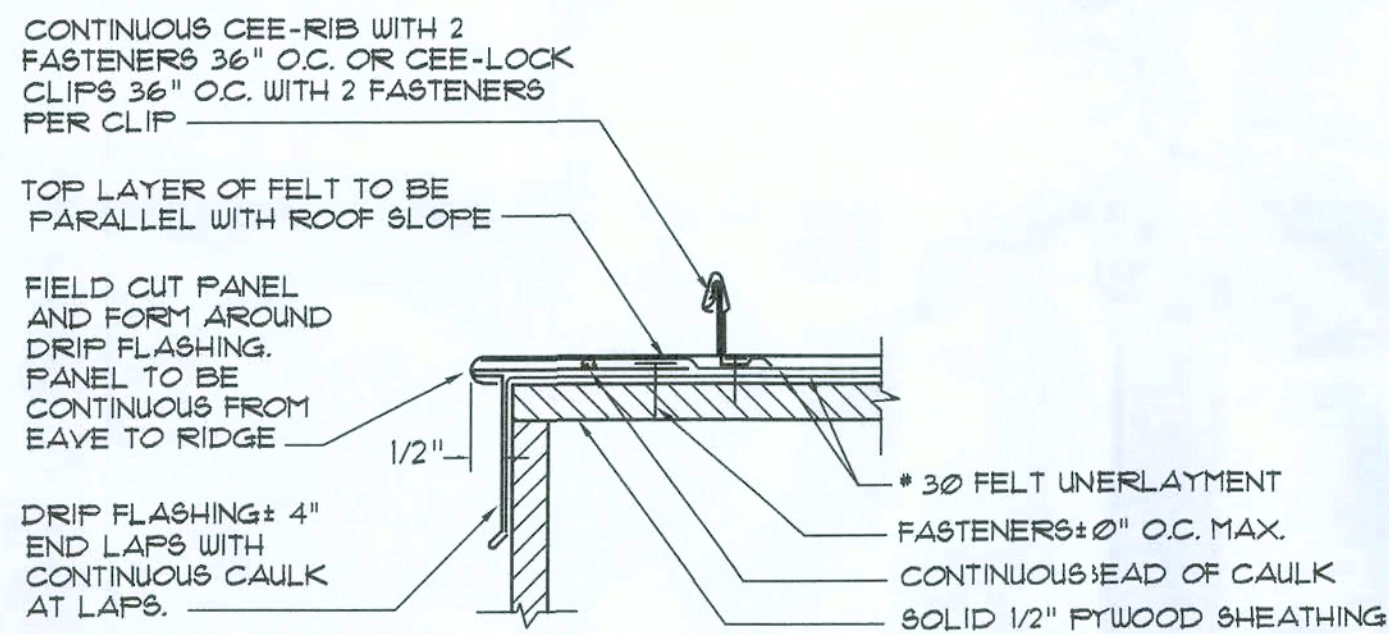


GABLE DETAIL / PANEL TURNDOWN

SCALE: NONE

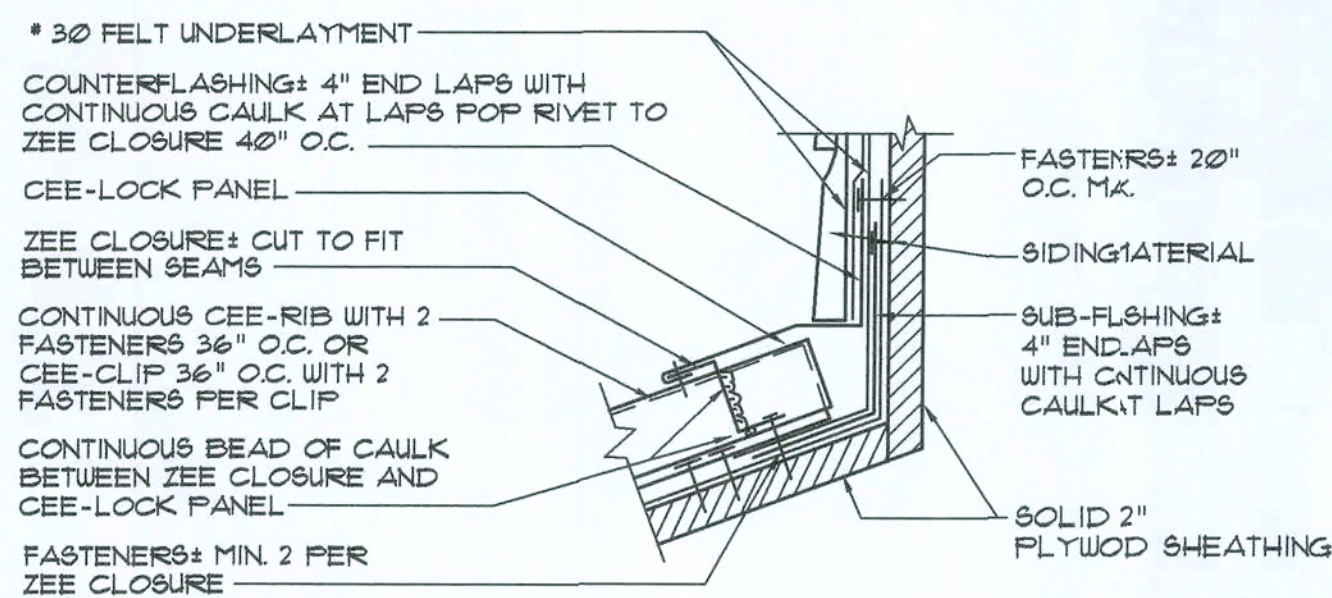


FLASHING DETAIL

SCALE: NONE

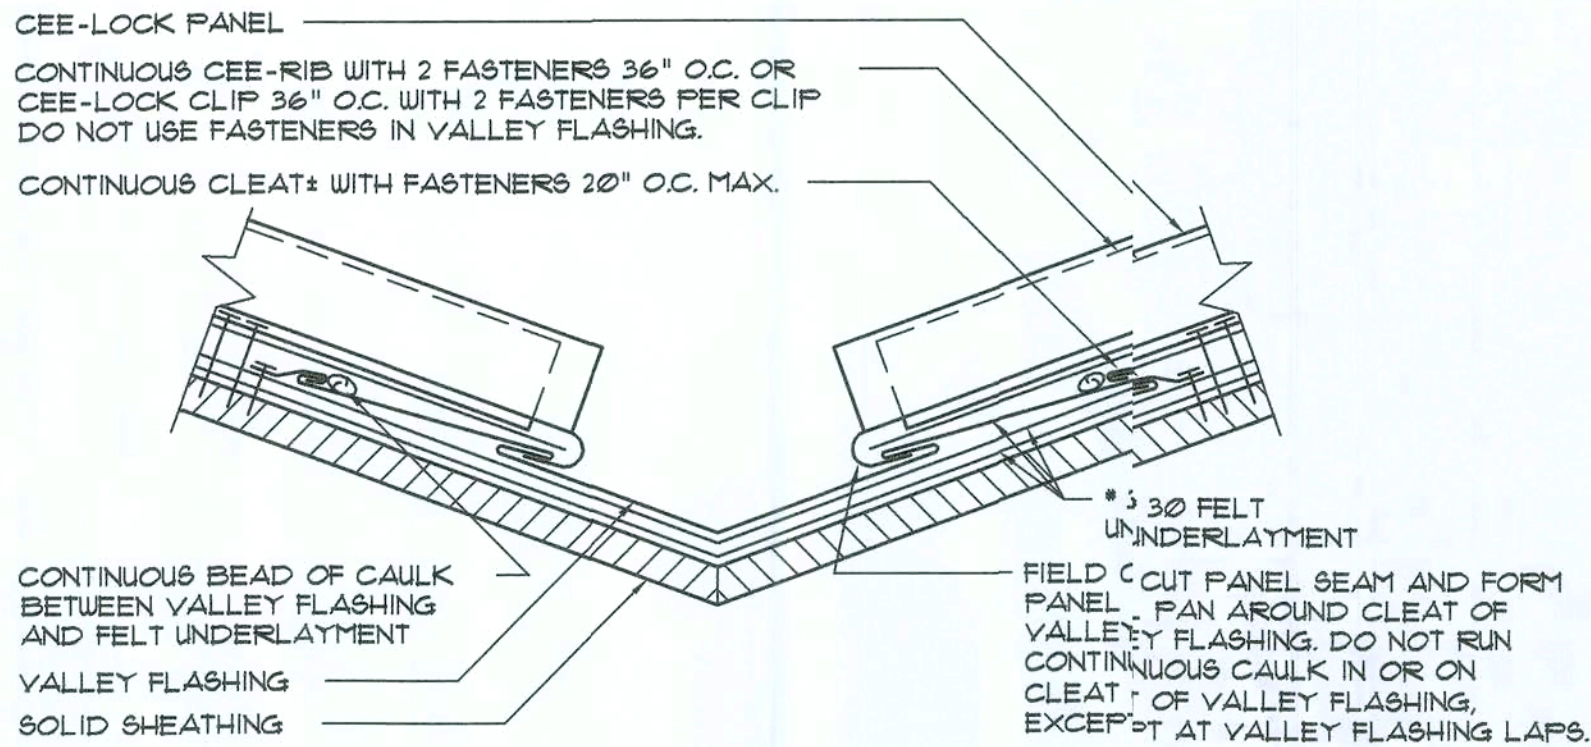

VALLEY DETAIL

SCALE: NONE

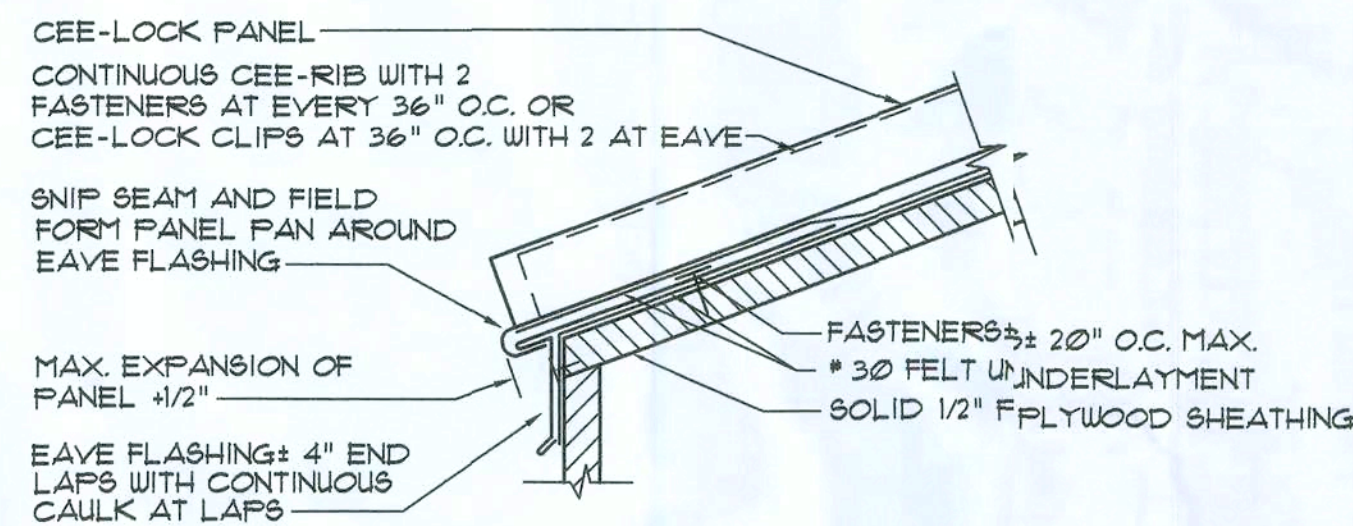


EAVE DETAIL

SCALE: NONE

NOTE: ALL FELT UNDERLAYMENT, CAULKING, AND FASTENERS SHALL BE FURNISHED AND INSTALLED BY THE ROOFING INSTALLER.

ALL ARCHITECTURAL PANELS ARE 24 GAUGE METAL. TAKE CARE IN HANDLING AND INSTALLATION TO AVOID DAMAGING OR DEFORMING THE PANELS.

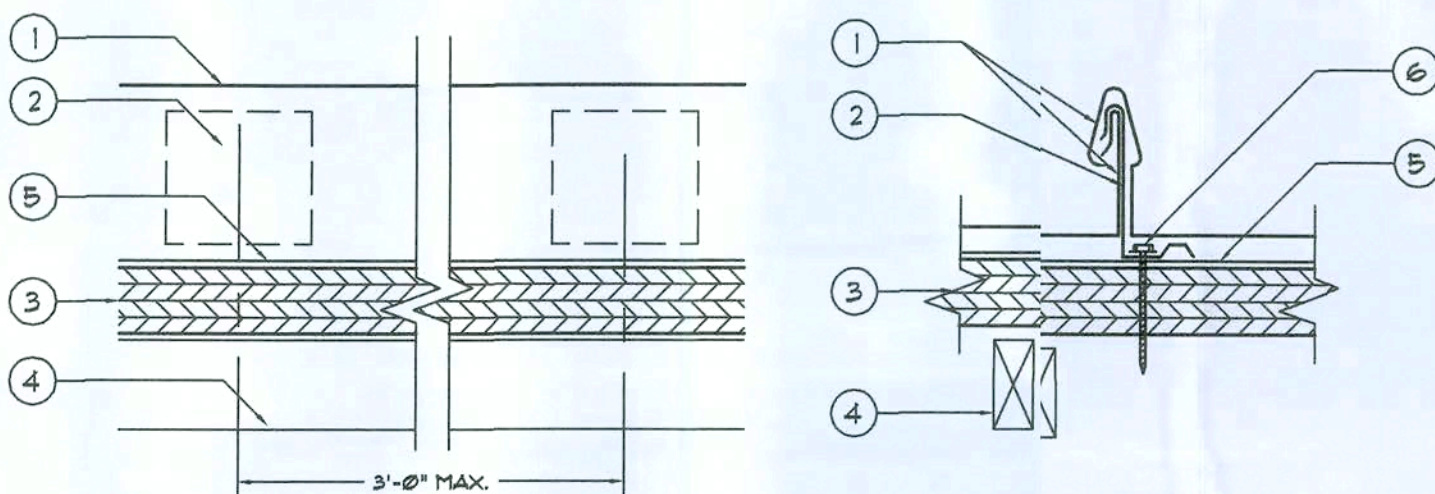

- CEE-LOCK PANEL - NO. 24 MSG (MIN. YIELD STRENGTH 40,000 PSI) THICKNESS COATED STEEL, 16 1/2 IN. WIDE 1 1/2 IN. HIGH. PANEL (NON-STRUCTURAL VINYL WEATHER SEAL OPTIONAL IN SEAM) CONTINUOUS OVER TWO OR MORE SPANS WITHOUT LAPS.
- CEE-CLIP (PANEL CLIP) - ONE PIECE ASSEMBLY FABRICATED FROM NO. 24 MSG (MIN. YIELD STRENGTH 40,000 PSI) COATED STEEL. CEE-CLIP LOCATED AT EACH PANEL SIDE LAPS BEING PLACED AT 3'-0" O.C. MAXIMUM.
- DECK - 5/8" APA 4070 PLYWOOD.
- JOIST - 2" X 4" AT 2'-0" O.C. MAXIMUM WITH #2 X 2" FAN HEAD, WOOD SCREW AT 12" O.C. MAX. AT PLYWOOD TO JOIST CONNECTION AND AT PLYWOOD ENDS.
- * 30 FELT UNDERLAYMENT.
- FASTENERS (SCREWS) - FOR ATTACHING "CEE-CLIP" (ITEM TWO) TO DECK USE NO. 10 PANCAKE HEAD TEK'S STEEL SCREWS, TWO FASTENER PER "CEE-CLIP".

CLIP FASTENER DETAIL

SCALE: NONE

THE STANDING SEAM METAL ROOF SYSTEM SHALL COMPLY WITH BERRIDGE MANUFACTURING COMPANY'S SPECIFICATIONS & DETAILS AS SHOWN ON THIS DRAWING, OR AN APPROVED PRODUCT OF EQUAL DESIGN.

BERRIDGE MANUFACTURING COMPANY
1120 MAURY STREET
HOUSTON, TX 77026
1-800-237-8121
<http://www.berridge.com>

METAL ROOFING INSTALLATION NOTES

- DOUBLE LAYER OF NUMBER THIRTY FELT UNDERLAYMENT OR EQUAL AND THE CEE-LOCK OPTIONAL VINYL WEATHERSEAL (US PATENT NO. 4,641,475) ARE RECOMMENDED FOR ALL APPLICATIONS WHERE THE ROOF SLOPE IS 3 ON 12 OR LESS.
- STRIPPABLE FILM: THE STRIPPABLE PLASTIC FILM WHICH IS APPLIED OVER MOST BERRIDGE PREFINISHED PRODUCTS, PANELS, FLASHINGS, COILS, AND FLAT SHEETS PROVIDES PROTECTION OF THE FINISH DURING FABRICATION AND TRANSIT. THIS FILM MUST BE REMOVED PRIOR TO INSTALLATION.
- SOLID SHEATHING REQUIREMENTS: 5/8" PLYWOOD SHEATHING SHALL BE USED TO PROVIDE SUFFICIENT HOLDING POWER FOR FASTENERS.
- SHEATHING INSPECTION:
 - SHEATHING END JOINTS SHOULD BE STAGGERED.
 - ALL END JOINTS SHOULD MEET AT EITHER A JOIST OR RAFTER.
 - BLOCKING OR "H" CLIPS SHOULD BE USED IF JOINTS DO NOT REMAIN FLAT UNDER THE WEIGHT OF WORKMEN.
 - USE SHIMS TO KEEP ENTIRE SUBSTRATE EVEN. UNEVEN SUBSTRATE WILL RESULT IN "OIL-CANNING" IN PANELS. SUBSTRATE SHOULD BE LEVEL TO 1/4" IN 20'-0".
 - ALL CUTS AT PENETRATIONS SHOULD BE TIGHT, WITHOUT GAPS.
 - USE WOOD-FRAMED CRICKETS AT LARGE PENETRATIONS.
 - MAKE SURE SUBSTRATE JOINTS ARE TIGHT AT ALL HIPS, VALLEYS, AND RIDGES.
- FASCIA/RAKE INSPECTION:
 - STRIKE A LINE THE FULL LENGTH OF THE FASCIA OR RAKE. IF NOT STRAIGHT, CORRECT WITH SHIMS.
 - MAKE SURE FASCIA/RAKE IS FLUSH WITH SHEATHING.
- FELT UNDERLAYMENT: A MINIMUM SINGLE LAYER OF * 30 FELT UNDERLAYMENT (OR EQUAL) MUST BE APPLIED OVER SOLID SHEATHING AS SHOWN IN THE BERRIDGE MANUFACTURING COMPANY TYPICAL FELTING DETAILS. THE USE OF ADDITIONAL LAYERS OF * 30 FELT IS RECOMMENDED ON LOW-SLOPED ROOFS, AT ALL VALLEY CONDITIONS, AT ROOF PENETRATIONS, AND CERTAIN OTHER FLASHING CONDITIONS AS DEPICTED IN THE CEE-LOCK PANEL TYPICAL DETAILS. (THE UNDERLAYMENT MUST COVER THE ENTIRE ROOF DECKED SURFACE).
- FELTING INSTALLATION:
 - DO NOT USE RED ROSIN PAPER UNDER METAL ROOFING PANELS.
 - SWEEP ROOF AREA CLEAN.
 - USE FLAT HEAD GALVANIZED ROOFING NAILS x 1 1/4" LONG WITH BERRIDGE GALVANIZED FELT CAPS.
 - INSTALL VALLEY FELT FIRST.
 - INSTALL FELT PARALLEL TO EAVE (2 LAYERS REQUIRED AT EAVE), STARTING AT EAVE AND USING MINIMUM 6" LAPS. USE TWO LAYERS OF FELT ON ENTIRE ROOF DECK IF ROOF SLOPE IS 3 ON 12 OR LESS. 2 LAYERS OF FELT REQUIRED AT EAVE REGARDLESS OF SLOPE.
 - FLASHING: IF BERRIDGE MANUFACTURING COMPANY IS TO SUPPLY FLASHINGS, ALL FLASHINGS WILL BE FABRICATED IN 10'-0" LENGTHS WITH SQUARE END CUTS ONLY. THE PURCHASER MUST PROVIDE ALL DIMENSIONS AND DEGREE OF ANGLES.
- FLASHING INSTALLATION:
 - REMOVE STRIPPABLE PLASTIC FILM FROM ALL FLASHINGS PRIOR TO INSTALLATION.
 - ALWAYS STAGGER JOINTS WHEN ONE FLASHING IS INSTALLED OVER OTHER FLASHING.
 - INSTALL ALL FLASHINGS AS PER BERRIDGE TYPICAL DETAILS.
 - ALL FLASHINGS ARE TO BE DESIGNED AND INSTALLED TO NOT TRAP WATER.
- PANEL INSTALLATION:
 - REMOVE STRIPPABLE PLASTIC FILM FROM EACH PANEL PRIOR TO INSTALLATION.
 - START PANEL INSTALLATION AT ON GABLE END OF THE ROOF WORKING TOWARD THE OTHER GABLE END. MAKE SURE PANELS ARE PERPENDICULAR TO THE EAVE. AT VALLEY AREAS, MAKE SURE PANELS ARE INSTALLED SO THAT DRAINAGE HAS FREE FLOW AND IS NOT OBSTRUCTED BY PANEL SEAMS.
 - BEGIN BY INSTALLING J-CLIP AND/OR DRIP FLASHING AT GABLE THEN PLACING FIRST CEE-LOCK CONTINUOUS LENGTH PANEL.
 - INSTALL CEE-LOCK CLIPS OR CONTINUOUS CEE-RIB AS PER BERRIDGE TYPICAL DETAILS AND CEE-LOCK CONTINUOUS RIB/CLIP INSTALLATION NOTES.
 - IF OPTIONAL VINYL WEATHERSEAL (US PATENT 4,641,475) IS TO BE USED, THIS WILL BE EITHER FACTORY INSTALLED OR INSTALLED IN THE FIELD AS THE CEE-LOCK PANEL EXITS FROM THE CL-21 FORTABLE ROLL FORMER.
 - INSTALL PANELS BY PLACING THE FEMALE LEG OVER THE MALE LEG AND CONTINUOUS CEE-RIB OR CLIP AND SNAPPING THE INTEGRAL BEAM INTO PLACE WITH HAND PRESSURE. DO NOT USE EXCESSIVE FORCE, FOOT PRESSURE OR OTHER TOOLS SUCH AS MALLETS AS THIS WILL SCRATCH OR DENT THE PANEL RIB AND CAUSE DEFORMATION TO THE VINYL WEATHERSEAL.
 - EACH PANEL IS TO BE KEPT TIGHT AGAINST THE LEG OF THE ADJOINING PANEL. NEVER PERMIT A GAP BETWEEN VERTICAL LEGS.
 - KEEP PANELS ALIGNED SO THAT SEAMS MATCH AT HIPS, VALLEYS AND WHERE VERTICAL PANELS ADJOIN ROOF PANELS. DO NOT INSTALL LONG CONTINUOUS RUNS OF PANELS ALL AT ONE TIME WHERE SEAM LINES MUST MATCH. INSTALL TEN OR TWELVE PANELS IN ONE ELEVATION AND THEN FOLLOW WITH A LIKE NUMBER OF PANELS ON THE OTHER ELEVATION. WHEN YOU INSTALL PANELS IN THIS MANNER YOU WILL BE ABLE TO MAKE ANY ADJUSTMENTS REQUIRED TO INSURE SEAM MATCHING.
 - COPPER-COTE, CHAMPAGNE, LEAD-COTE, AND PREWEATHER GALVALUME PANEL INSTALLATION: NOTE THE SERIES OF ARROWS PAINTED ON THE UNDERSIDE OF THE PANEL. ALL PANELS MUST BE INSTALLED IN CONSISTENT MANNER, MEANING THAT THE ARROWS ON EVERY PANEL ARE ALL POINTING IN THE SAME DIRECTION. IF A PANEL IS REVERSED (ARROWS POINTING OPPOSITE OF THOSE ON OTHER PANELS) IT WILL APPEAR FROM A DISTANCE, A DIFFERENT SHADE DUE TO THE GRANULAR OF THE PIGMENTS IN THE FINISH. METALLIC FINISHES ARE MATCH - LOT FINISHES. DO NOT MIX LOTS.
- CEE-LOCK CLIP INSTALLATION:
 - INSTALL CLIPS AS PER BERRIDGE TYPICAL CEE-LOCK PANEL DETAILS.
 - CLIP SPACING ON SOLID SHEATHING TYPICALLY 36" ON CENTER.
- FASTENERS:

FLATED FASTENERS WHEN FASTENING TO WOOD. MAKE SURE ALL FASTENERS ARE DRIVEN STRAIGHT AND SET FLAT. DO NOT OVERDRIVE FASTENERS AS THIS WILL CAUSE THE CLIP AND/OR FLASHINGS TO BUCKLE OR BECOME RECESSED BELOW THE ELEVATION OF THE SUBSTRATE.
- SEALANT RECOMMENDATIONS: TREMCO, INC. SPECTREM 1 SILICONE SEALANT. DO NOT USE CLEAR CAULK.

THESE INSTALLATION INSTRUCTIONS AND THE FOLLOWING TYPICAL DETAILS ARE INTENDED TO PROVIDE OUR CUSTOMERS WITH THE INFORMATION REQUIRED FOR AN AESTHETICALLY PLEASING AND FUNCTIONAL INSTALLATION OF THE BERRIDGE CEE-LOCK STANDING SEAM ROOF PANEL SYSTEM.

Digitally signed by N.P. Giesler
DN: cn = N.P. Giesler, c = US
o = AR0007005, ou = ARCHITECT
Date: 2020.08.20 10:45:45 -0500


REVISION:

Copyright 2020
N.P. Giesler, Architect

DRAWN:

mpg

ASSISTED LIVING FACILITY for
GRANDE CYPRESS
LAKE CITY, COLUMBIA COUNTY, FLORIDA
METAL ROOFING DETAILS

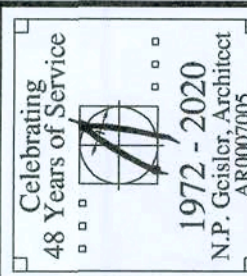

NICHOLAS PAUL GIESLER
ARCHITECT
N.C.A.R.B. Certified

DATE:

18 AUG 2020

COMM:

2K2040

SHEET

A.11

1 OF 11

AR0007005

These drawings, as instruments of service, are the sole property of the architect, and may not be used, copied or reproduced in whole or in part, for use in or incorporated into any other job without specific and individual authorization by the architect.

FLORIDA BUILDING CODE	
Compliance Summary	
TYPE OF CONSTRUCTION	
Roof: Hip / Gable Construction, Wood Trusses @ 24" O.C. Walls: 2x6 Wood Studs @ 16" O.C. Floor: 4" Thk. Concrete Slab w/ Fiberglass Concrete Additive Foundation: Continuous Monolithic Slab-Footer	
ROOF DECKING	
Material: 1/2" CD Plywood or 1/4" OSB Sheet Size: 48"x96" Sheets Perpendicular to Roof Framing Fasteners: 8d Ring Shank Nails per schedule on sheet 5.5	
SHEAR WALLS	
Material: 1/6" OSB, Windstorm: 48" x 96" 102", 121" or 145" Sheet Size: 48"x96" Sheets Perpendicular to Wall Framing Fasteners: 8d Ring Shank Nails @ 4" O.C. Edges @ 8" O.C. Interior Dragstrut: Double Top Plate (S.Y.F.) w/ 2 - 16d Nails @ 12" O.C. Wall Studs: 2x6 SFF Studs @ 16" O.C.	
HURRICANE UPLIFT CONNECTORS	
Truss Anchors: Simpson H2.5a @ Ea. Truss End (Typ. UON) Wall Tension: Wall Sheathing Nailing is Adequate - 8d @ 4" O.C. Top & Bot. Anchor Bolts: 1/2" x 50" @ 48" O.C. - 1x4 Bolt @ 8' from corner Corner Hold-down Device: Simpson HD2a, ea. corner	
FOOTINGS AND FOUNDATIONS	
Footings: 16"x18" Cont. Mono/W-15 Cont. 4 wire chairs @ 48" O.C.	

BUILDING COMPONENTS & CLADDING LOADS	
MEAN BUILDING HEIGHT = 30.0', EXPOSURE "B"	
ROOF ANGLE 1" TO 21"	
ZONE	AREA
1	2
10	12.0 / -19.3
10	14.4 / -19.4
10	10.0 / -18.6
10	12.5 / -34.7
10	14.4 / -31.5
10	10.0 / -28.2
10	12.5 / -51.3
10	14.4 / -47.5
10	10.0 / -43.5
10	12.5 / -71.2
10	14.4 / -67.5
10	10.0 / -63.5
10	12.5 / -91.1
10	14.4 / -87.5
10	10.0 / -83.5
10	12.5 / -110.7
10	14.4 / -107.1
10	10.0 / -103.1
10	12.5 / -130.3
10	14.4 / -126.7
10	10.0 / -122.7
10	12.5 / -150.0
10	14.4 / -146.4
10	10.0 / -142.4
10	12.5 / -169.7
10	14.4 / -166.1
10	10.0 / -162.1
10	12.5 / -189.4
10	14.4 / -185.8
10	10.0 / -181.8
10	12.5 / -209.1
10	14.4 / -205.5
10	10.0 / -201.5
10	12.5 / -228.8
10	14.4 / -225.2
10	10.0 / -221.2
10	12.5 / -248.5
10	14.4 / -244.9
10	10.0 / -240.9
10	12.5 / -268.2
10	14.4 / -264.6
10	10.0 / -260.6
10	12.5 / -287.5
10	14.4 / -283.9
10	10.0 / -279.9
10	12.5 / -307.2
10	14.4 / -303.6
10	10.0 / -299.6
10	12.5 / -326.5
10	14.4 / -322.9
10	10.0 / -318.9
10	12.5 / -345.8
10	14.4 / -342.2
10	10.0 / -338.2
10	12.5 / -365.5
10	14.4 / -361.9
10	10.0 / -357.9
10	12.5 / -384.8
10	14.4 / -381.2
10	10.0 / -377.2
10	12.5 / -404.5
10	14.4 / -400.9
10	10.0 / -396.9
10	12.5 / -423.8
10	14.4 / -419.2
10	10.0 / -415.2
10	12.5 / -442.5
10	14.4 / -438.9
10	10.0 / -434.9
10	12.5 / -461.8
10	14.4 / -458.2
10	10.0 / -454.2
10	12.5 / -481.5
10	14.4 / -477.9
10	10.0 / -473.9
10	12.5 / -500.8
10	14.4 / -497.2
10	10.0 / -493.2
10	12.5 / -520.5
10	14.4 / -516.9
10	10.0 / -512.9
10	12.5 / -540.8
10	14.4 / -537.2
10	10.0 / -533.2
10	12.5 / -560.5
10	14.4 / -556.9
10	10.0 / -552.9
10	12.5 / -580.8
10	14.4 / -577.2
10	10.0 / -573.2
10	12.5 / -600.5
10	14.4 / -596.9
10	10.0 / -592.9
10	12.5 / -620.8
10	14.4 / -617.2
10	10.0 / -613.2
10	12.5 / -640.5
10	14.4 / -636.9
10	10.0 / -632.9
10	12.5 / -660.8
10	14.4 / -657.2
10	10.0 / -653.2
10	12.5 / -680.5
10	14.4 / -676.9
10	10.0 / -672.9
10	12.5 / -700.8
10	14.4 / -697.2
10	10.0 / -693.2
10	12.5 / -720.5
10	14.4 / -716.9
10	10.0 / -712.9
10	12.5 / -740.8
10	14.4 / -737.2
10	10.0 / -733.2
10	12.5 / -760.5
10	14.4 / -756.9
10	10.0 / -752.9
10	12.5 / -780.8
10	14.4 / -777.2
10	10.0 / -773.2
10	12.5 / -800.5
10	14.4 / -796.9
10	10.0 / -792.9
10	12.5 / -820.8
10	14.4 / -817.2
10	10.0 / -813.2
10	12.5 / -840.5
10	14.4 / -836.9
10	10.0 / -832.9
10	12.5 / -860.8
10	14.4 / -857.2
10	10.0 / -853.2
10	12.5 / -880.5
10	14.4 / -876.9
10	10.0 / -872.9
10	12.5 / -900.8
10	14.4 / -897.2
10	10.0 / -893.2
10	12.5 / -920.5
10	14.4 / -916.9
10	10.0 / -912.9
10	12.5 / -940.8
10	14.4 / -937.2
10	10.0 / -933.2
10	12.5 / -960.5
10	14.4 / -956.9
10	10.0 / -952.9
10	12.5 / -980.8
10	14.4 / -977.2
10	10.0 / -973.2
10	12.5 / -1000.5
10	14.4 / -996.9
10	10.0 / -992.9
10	12.5 / -1020.8
10	14.4 / -1017.2
10	10.0 / -1013.2
10	12.5 / -1040.5
10	14.4 / -1036.9
10	10.0 / -1032.9
10	12.5 / -1060.8
10	14.4 / -1057.2
10	10.0 / -1053.2
10	12.5 / -1080.5
10	14.4 / -1076.9
10	10.0 / -1072.9
10	12.5 / -1100.8
10	14.4 / -1097.2
10	10.0 / -1093.2
10	12.5 / -1120.5
10	14.4 / -1116.9
10	10.0 / -1112.9
10	12.5 / -1140.8
10	14.4 / -1137.2
10	10.0 / -1133.2
10	12.5 / -1160.5
10	14.4 / -1156.9
10	10.0 / -1152.9
10	12.5 / -1180.8
10	14.4 / -1177.2
10	10.0 / -1173.2
10	12.5 / -1200.5
10	14.4 / -1196.9
10	10.0 / -1192.9
10	12.5 / -1220.8
10	14.4 / -1217.2
10	10.0 / -1213.2
10	12.5 / -1240.5
10	14.4 / -1236.9
10	10.0 / -1232.9
10	12.5 / -1260.8
10	14.4 / -1257.2
10	10.0 / -1253.2
10	12.5 / -1280.5
10	14.4 / -1276.9
10	10.0 / -1272.9
10	12.5 / -1300.8
10	14.4 / -1297.2
10	10.0 / -1293.2
10	12.5 / -1320.5
10	14.4 / -1316.9
10	10.0 / -1312.9
10	12.5 / -1340.8
10	14.4 / -1337.2
10	10.0 / -1333.2
10	12.5 / -1360.5
10	14.4 / -1356.9
10	10.0 / -1352.9
10	12.5 / -1380.8
10	14.4 / -1377.2
10	10.0 / -1373.2
10	12.5 / -1400.5
10	14.4 / -1396.9
10	10.0 / -1392.9
10	12.5 / -1420.8
10	14.4 / -1417.2
10	10.0 / -1413.2
10	12.5 / -1440.5
10	14.4 / -1436.9
10	10.0 / -1432.9
10	12.5 / -1460.8
10	14.4 / -1457.2
10	10.0 / -1453.2
10	12.5 / -1480.5
10	14.4 / -1476.9
10	10.0 / -1472.9
10	12.5 / -1500.8
10	14.4 / -1497.2
10	10.0 / -1493.2
10	12.5 / -1520.5
10	14.4 / -1516.9
10	10.0 / -1512.9
10	12.5 / -1540.8
10	14.4 / -1537.2
10	10.0 / -1533.2
10	12.5 / -1560.5
10	14.4 / -1556.9
10	10.0 / -1552.9
10	12.5 / -1580.8
10	14.4 / -1577.2
10	10.0 / -1573.2
10	12.5 / -1600.5
10	14.4 / -1596.9
10	10.0 / -1592.9
10	12.5 / -1620.8
10	14.4 / -1617.2
10	10.0 / -1613.2
10	12.5 / -1640.5
10	14.4 / -1636.9
10	10.0 / -1632.9
10	12.5 / -1660.8
10	14.4 / -1657.2
10	10.0 / -1653.2
10	12.5 / -1680.5
10	14.4 / -1676.9
10	10.0 / -1672.9
10	12.5 / -1700.8
10	14.4 / -1697.2
10	10.0 / -1693.2
10	12.5 / -1720.5
10	14.4 / -1716.9
10	10.0 / -1712.9
10	12.5 / -1740.8
10	14.4 / -1737.2
10	10.0 / -1733.2
10	12.5 / -1760.5
10	14.4 / -1756.9
10	10.0 / -1752.9
10	12.5 / -1780.8
10	14.4 / -1777.2
10	10.0 / -1773.2
10	12.5 / -1800.5
10	14.4 / -1796.9
10	10.0 / -1792.9
10	12.5 / -1820.8
10	14.4 / -1817.2
10	10.0 / -1813.2
10	12.5 / -1840.5
10	14.4 / -1836.9
10	10.0 / -1832.9
10	12.5 / -1860.8
10	14.4 / -1857.2
10	10.0 / -1853.2
10	12.5 / -1880.5
10	14.4 / -1876.9
10	10.0 / -1872.9
10	12.5 / -1900.8
10	14.4 / -1897.2
10	10.0 / -1893.2
10	12.5 / -1920.5
10	14.4 / -1916.9
10	10.0 / -1912.9
10	12.5 / -1940.8
10	14.4 / -1937.2
10	10.0 / -1933.2
10	12.5 / -1960.5
10	14.4 / -1956.9
10	10.0 / -1952.9
10	12.5 / -1980.8
10	14.4 / -1977.2
10	10.0 / -1973.2
10	12.5 / -2000.5
10	14.4 / -1996.9
10	10.0 / -1992.9
10	12.5 / -2020.8
10	14.4 / -2017.2
10	10.0 / -2013.2
10	12.5 / -2040.5
10	14.4 / -2036.9
10	10.0 / -2032.9
10	12.5 / -2060.8
10	14.4 / -2057.2
10	10.0 / -2053.2
10	12.5 / -2080.5
10	14.4 / -2076.9
10	10.0 / -2072.9
10	12.5 / -2100.8
10	14.4 / -2097.2
10	10.0 / -2093.2
10	12.5 / -2120.5
10	14.4 / -2116.9
10	10.0 / -2112.9
10	12.5 / -2140.8
10	14.4 / -2137.2
10	10.0 / -2133.2
10	12.5 / -2160.5
10	14.4 / -2156.9
10	10.0 / -2152.9
10	12.5 / -2180.8
10	14.4 / -2177.2
10	10.0 / -2173.2
10	12.5 / -2200.5
10	14.4 / -2196.9
10	10.0 / -2192.9
10	12.5 / -2220.8
10	14.4 / -2217.2
10	10.0 / -2213.2
10	12.5 / -2240.5
10	14.4 / -2236.9
10	10.0 / -2232.9
10	12.5 / -2260.8
10	14.4 / -2257.2
10	10.0 / -2253.2
10	12.5 / -2280.5
10	14.4 / -2276.9
10	10.0 / -2272.9
10	12.5 / -2300.8
10	14.4 / -2297.2
10	10.0 / -2293.2
10	12.5 / -2320.5
10	14.4 / -2316.9
10	10.0 / -2312.9
10	12.5 / -2340.8
10	14.4 / -2337.2
10	10.0 / -2333.2
10	12.5 / -2360.5
10	14.4 / -2356.9
10	10.0 / -2352.9
10	12.5 / -2380.8
10	14.4 / -2377.2
10	10.0 / -2373.2
10	12.5 / -2400.5
10	14.4 / -2396.9
10	10.0 / -2392.9
10	12.5 / -2420.8
10	14.4 / -2417.2
10	10.0 / -2413.2
10	12.5 / -2440.5
10	14.4 / -2436.9
10	10.0 / -2432.9
10	12.5 / -2460.8
10	14.4 / -2457.2
10	10.0 / -2453.2
10	12.5 / -2480.5
10	14.4 / -2476.9
10	10.0 / -2472.9
10	12.5 / -2500.8
10	14.4 / -2497.2
10	10.0 / -2493.2
10	12.5 / -2520.5
10	14.4 / -2516.9
10	10.0 / -2512.9
10	12.5 / -2540.8
10	14.4 / -2537.2
10	10.0 / -2533.2
10	12.5 / -2560.5
10	14.4 / -2556.9
10	10.0 / -2552.9
10	12.5 / -2580.8
10	14.4 / -2577.2
10	10.0 / -2573.2
10	12.5 / -2600.5
10	14.4 / -2596.9
10	10.0 / -2592.9
10	12.5 / -2620.8
10	14.4 / -2617.2
10	10.0 / -2613.2
10	12.5 / -2640.5
10	14.4 / -2636.9
10	10.0 / -2632.9
10	12.5 / -2660.8
10	14.4 / -2657.2
10	10.0 / -2653.2
10	12.5 / -2680.5
10	14.4 / -2676.9
10	10.0 / -2672.9
10	12.5 / -2700.8
10	14.4 / -2697.2
10	10.0 / -2693.2
10	12.5 / -2720.5
10	14.4 / -2716.9
10	10.0 / -2

SCALE: 1/8" = 1'-0"

PROVIDE A 16"x14" X CONT. MONOLITHIC CONC. FOOTING W/ 2 # REBAR, BOTTOM & WIRE CHAIRS @ 48" O.C. - UNDER ALL PORCH PERIMETER

NOTE1
THE DESIGN WIND SPEED FOR THIS
PROJECT IS 130 MPH PER 2011 FBC 1609
AND LOCAL JURISDICTION REQUIREMENTS

TUD-PACK POST LOCATIONS
05 EACH, 12 LOCATIONS
ENGINEERING REACTION LOADS,
WILL BE REQUIRED PRIOR TO
DURING CONCRETE

SCALE: 1/2" = 1'-0"



151
DRAWINGS INDICATING ALL PLUMBING WORK INCLUDING ALL
DRAINING LINE LOCATIONS AND RISER DIAGRAM - CONTR
COPY TO THE PERMIT ISSUING AUTHORITY.
151
A/C CONTRACTOR SHALL PREPARE "AS-BUILT" SHOP
DRAWINGS INDICATING ALL HVAC WORK INCLUDING ALL
DRAINAGE AND CONDENSATE PIPING, EQUIPMENT SOIL & BALANCING
VALVES, AIR FLOW, AIR PRESSURE, AIR VOLUME, AIR TEMPERATURE
AND AIR HUMIDITY. PROVIDE 1 COPY OF "AS-BUILT" DRAW
INGS TO THE PERMIT ISSUING AUTHORITY.

TO THE CONSTRUCTION OF THE FOUNDATION,
A CONTRACTOR SHALL COORDINATE ANY INTERIOR
DRAINING LOCATION CONDITIONS WITH THE TRUSS
DESIGNER. ANY INTERIOR BEARING LOCATIONS OR ANY
INTERIOR LOADS OF 40 K OR GREATER SHALL BE
SUPPORTED VIA A MODIFIED FOUNDATION PLAN
DRAWING. THESE LOADS MUST BE CONSIDERED IN THE
DESIGN OF THE FOUNDATION. THE ENGINEERED TRUSS
DESIGNER SHALL MAKE THE ENGINEERED TRUSS
DESIGNER RESPONSIBLE FOR THE ARCHITECT FOR
THE PURPOSE OF REDESIGNING SUCH MODIFICATIONS
FOR TO POURING ANY CONCRETE.

CONCRETE / MASONRY /
METALS GENERAL NOTES:


CONSTRUCTION NOTES

[illegible]

6X6 GYP P/T WD. POSTS

02 SEP 2020

These drawings, as instruments of service, are the sole property of the architect, and may not be used, copied or reproduced in whole or in part for use on or incorporated within any other job without specific and individual authorization by the architect.

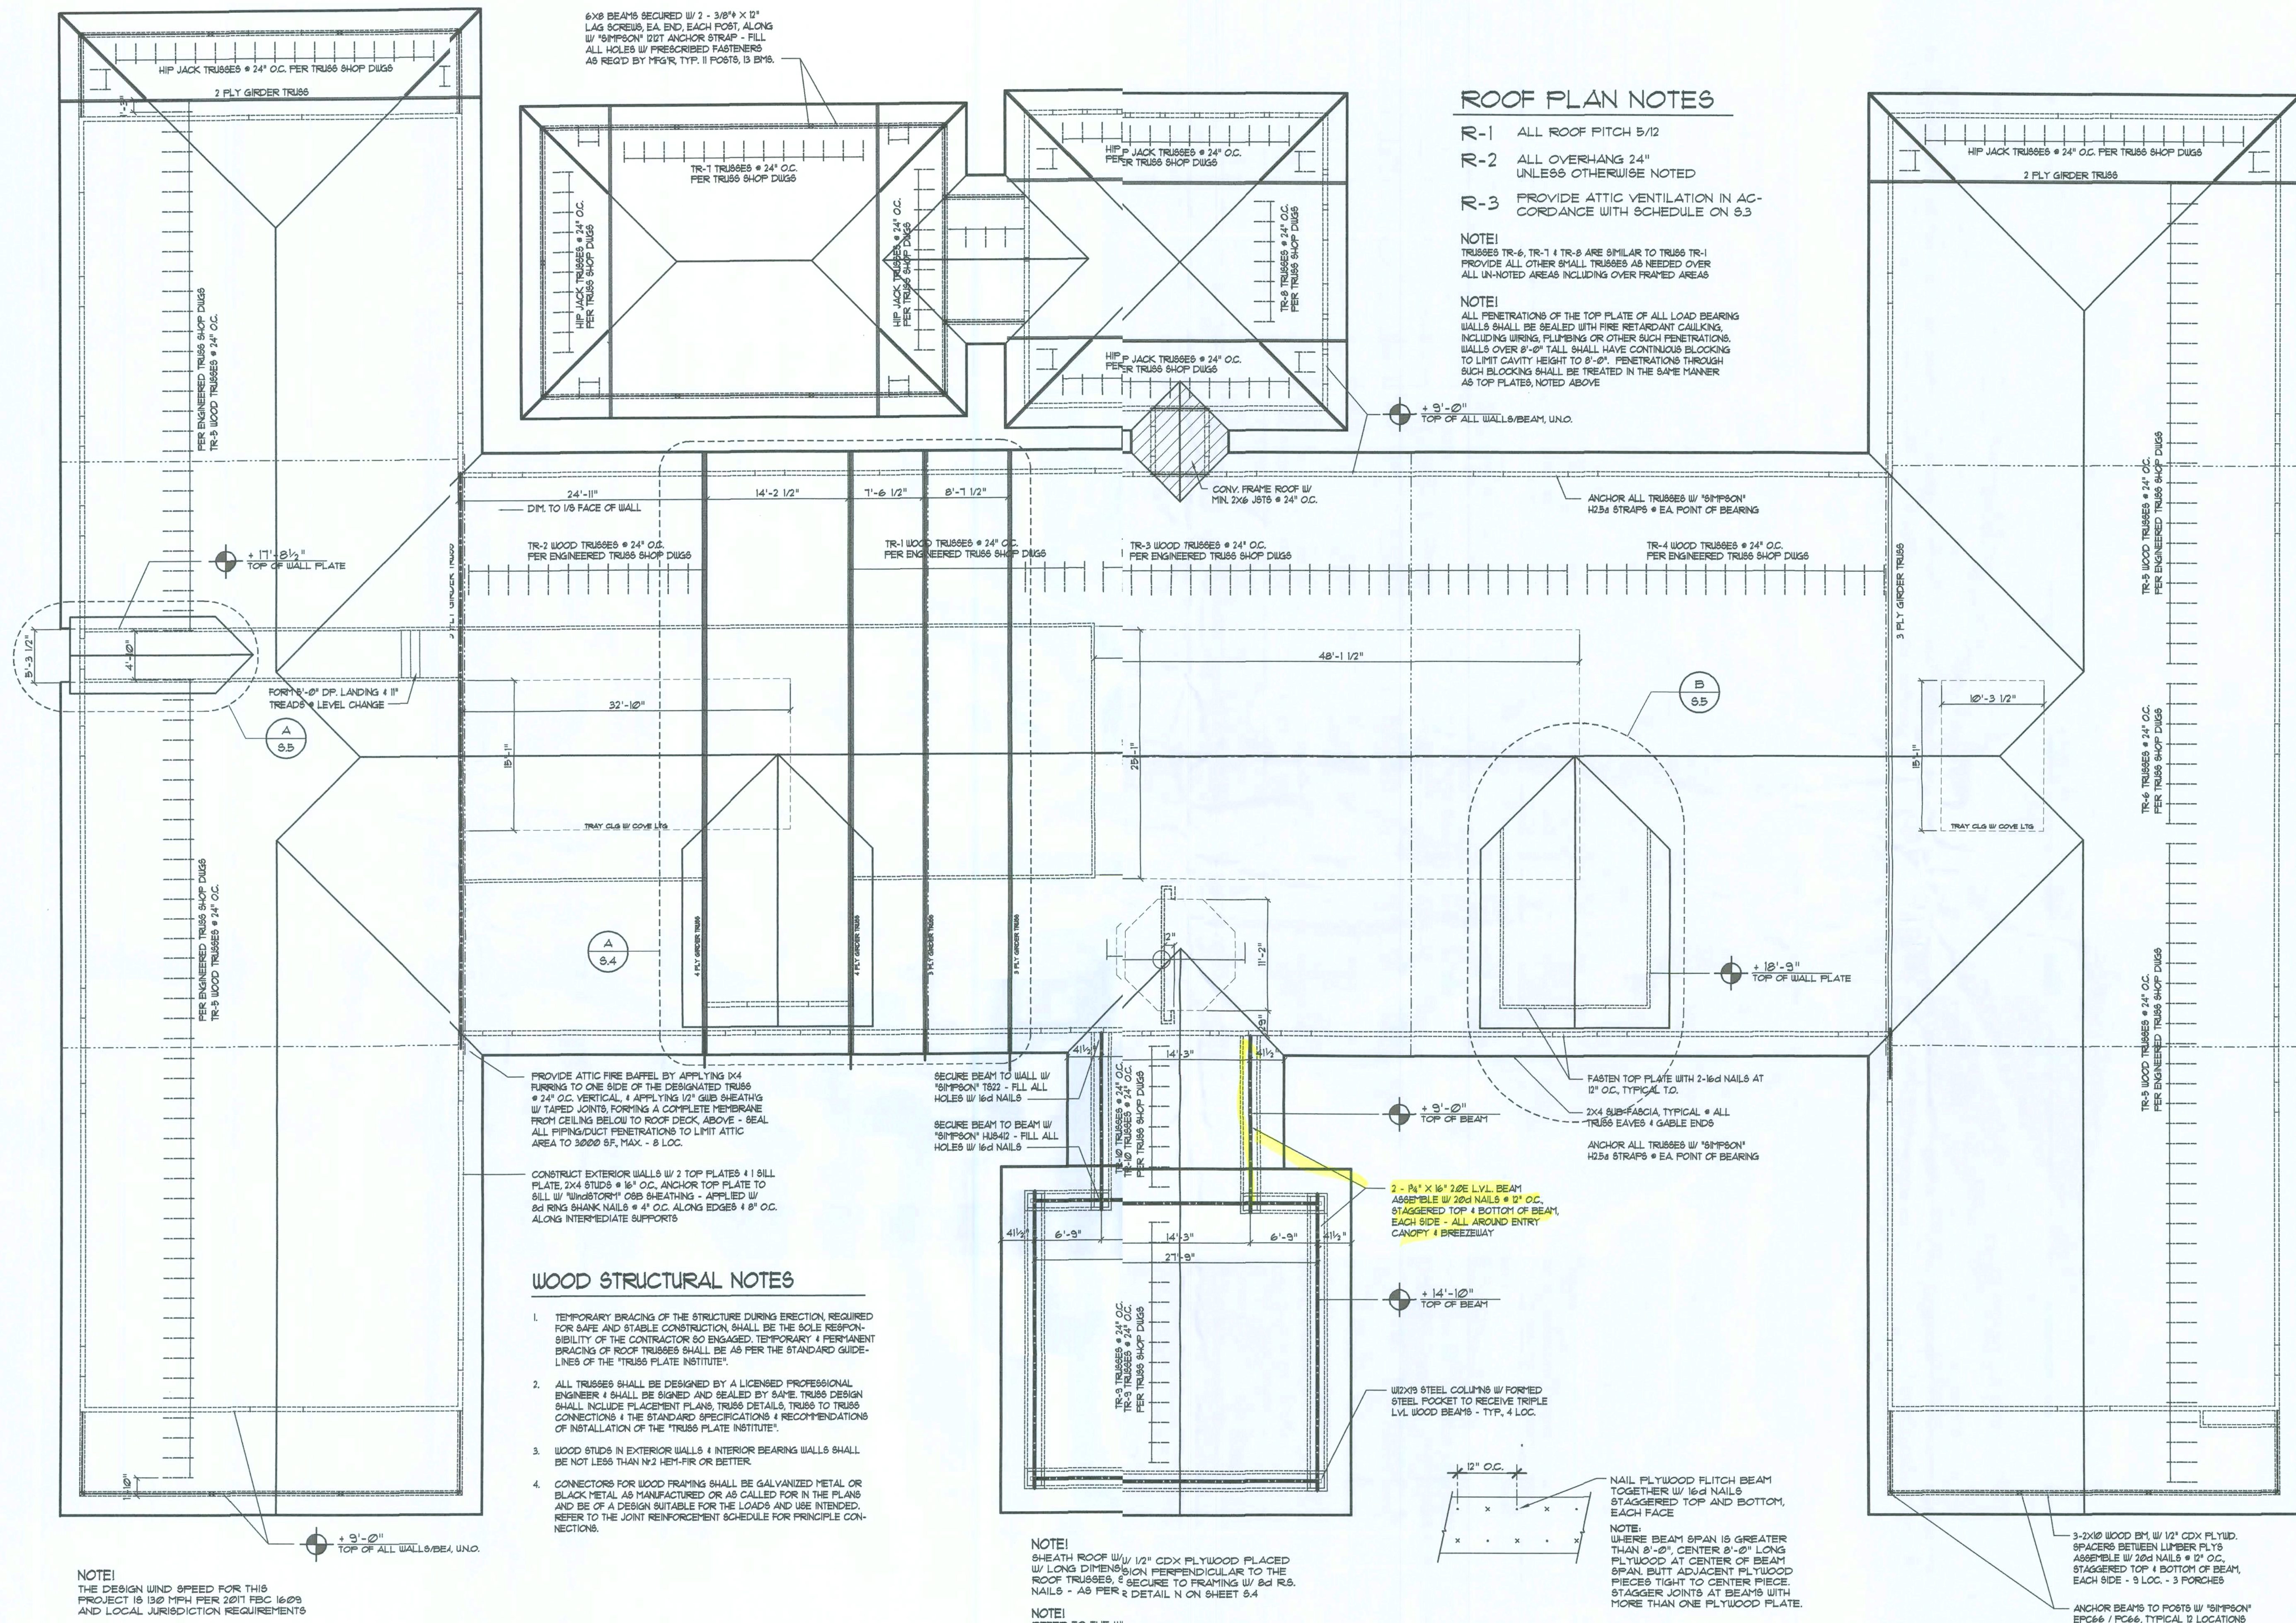

REVISION:
01 SEP 2020

Copyright, 2020
N.P. Gesler, Architect

DRAWN:
mg

ASSISTED LIVING FACILITY for
SMITH - SORENSEN
LAKE CITY, COLUMBIA COUNTY, FLORIDA

ROOF PLAN

48 Years of Service

1972-2020
N.P. Gesler, Architect
AR0007005

NICHOLAS
GESLER
ARCHITECT
N.C.A.R.B. Certified

1725 NW Brown Rd.
Gainesville, FL 32609
352-365-4355

DATE
18 AUG 2020

CONTRACT
2K2040

SHEET:
S.3
3 OF 6

Digitally signed by: N.P. GESLER
DN: cn = N.P. GESLER, c = US
Date: 2020.08.03 09:55:11 -0500

AR0007005

NOTE!
THE DESIGN WIND SPEED FOR THIS
PROJECT IS 130 MPH PER 2017 FBC 1609
AND LOCAL JURISDICTION REQUIREMENTS

ROOF FRAMING PLAN

SCALE: 1/8" = 1'-0"

ROOF PLAN NOTES

R-1 ALL ROOF PITCH 5/12

R-2 ALL OVERHANG 24"
UNLESS OTHERWISE NOTED

R-3 PROVIDE ATTIC VENTILATION IN AC-
CORDANCE WITH SCHEDULE ON S.3

NOTE!
TRUSSES TR-6, TR-7 & TR-8 ARE SIMILAR TO TRUSSES TR-1
PROVIDE ALL OTHER SMALL TRUSSES AS NEEDED OVER
ALL UN-NOTED AREAS INCLUDING OVER FRAMED AREAS

NOTE!
ALL PENETRATIONS OF THE TOP PLATE OF ALL LOAD BEARING
WALLS SHALL BE SEALED WITH FIRE RETARDANT CAULKING,
INCLUDING WIRING, PLUMBING OR OTHER SUCH PENETRATIONS.
WALLS OVER 8'-0" TALL SHALL HAVE CONTINUOUS BLOCKING
TO LIMIT CAVITY HEIGHT TO 8'-0". PENETRATIONS THROUGH
SUCH BLOCKING SHALL BE TREATED IN THE SAME MANNER
AS TOP PLATES, NOTED ABOVE

+ 9'-0"
TOP OF ALL WALLS/BEAM, UNO.

ANCHOR ALL TRUSSES W/ "SIMPSON"
H2S STRAPS @ EA POINT OF BEARING

B
S.5

+ 18'-9"
TOP OF WALL PLATE

FASTEN TOP PLATE WITH 2-16d NAILS AT
12" O.C. TYPICAL T.O.
2X4 SUB-FASCIA, TYPICAL @ ALL
TRUSS EAVES & GABLE ENDS
ANCHOR ALL TRUSSES W/ "SIMPSON"
H2S STRAPS @ EA POINT OF BEARING

+ 9'-0"
TOP OF BEAM

+ 14'-10"
TOP OF BEAM

WOOD STEEL COLUMNS W/ FORMED
STEEL POCKET TO RECEIVE TRIPLE
LVL WOOD BEAMS - TYP. 4 LOC.

NAIL PLYWOOD FLITCH BEAM
TOGETHER W/ 16d NAILS
STAGGERED TOP AND BOTTOM,
EACH FACE
NOTE:
WHERE BEAM SPAN IS GREATER
THAN 8'-0", CENTER 8'-0" LONG
PLYWOOD AT CENTER OF BEAM
SPAN, BUT ADJACENT PLYWOOD
PIECES TIGHT TO CENTER PIECE.
STAGGER JOINTS AT BEAMS WITH
MORE THAN ONE PLYWOOD PLATE.

B/U Beam DETAILS

SCALE: NONE

NOTE!
SHEATH ROOF W/ 1/2" CDX PLYWOOD PLACED
W/ LONG DIMENSIONS PERPENDICULAR TO THE
ROOF TRUSSES, & SECURE TO FRAMING W/ 8d RS.
NAILS - AS PER DETAIL N ON SHEET S.4

NOTE!
REFER TO THE WINDOW/DOOR HEADER
SCHEDULE ON SHEET S.4 FOR ALL
MINIMUM SIZE HEADERS AND ALTERNATES
MINIMUM SIZE ALLOWABLE IS 2-2X10.


PROVIDE ATTIC FIRE BARRIEL BY APPLYING 1X4
FURRING TO ONE SIDE OF THE DESIGNATED TRUSS
@ 24" O.C. VERTICAL, & APPLYING 1/2" GIB SHEATHING
W/ TAPED JOINTS, FORMING A COMPLETE MEMBRANE
FROM CEILING BELOW TO ROOF DECK, ABOVE - SEAL
ALL PIPING/DUCT PENETRATIONS TO LIMIT ATTIC
AREA TO 3000 SF, MAX. - 3 LOC.

CONSTRUCT EXTERIOR WALLS W/ 2 TOP PLATES & 1 SILL
PLATE, 2X4 STUDS @ 16" O.C., ANCHOR TOP PLATE TO
SILL W/ "WINDSTORM" OSB SHEATHING - APPLIED W/
8d RING SHANK NAILS @ 4" O.C. ALONG EDGES & 8" O.C.
ALONG INTERMEDIATE SUPPORTS


WOOD STRUCTURAL NOTES

1. TEMPORARY BRACING OF THE STRUCTURE DURING ERECTION, REQUIRED
FOR SAFE AND STABLE CONSTRUCTION, SHALL BE THE SOLE RESPONSIBILITY
OF THE CONTRACTOR SO ENGAGED. TEMPORARY & PERMANENT
BRACING OF ROOF TRUSSES SHALL BE AS PER THE STANDARD GUIDE-
LINES OF THE "TRUSS PLATE INSTITUTE".
2. ALL TRUSSES SHALL BE DESIGNED BY A LICENSED PROFESSIONAL
ENGINEER & SHALL BE SIGNED AND SEALED BY SAME. TRUSS DESIGN
SHALL INCLUDE PLACEMENT PLANS, TRUSS DETAILS, TRUSS TO TRUSS
CONNECTIONS & THE STANDARD SPECIFICATIONS & RECOMMENDATIONS
OF INSTALLATION OF THE "TRUSS PLATE INSTITUTE".
3. WOOD STUDS IN EXTERIOR WALLS & INTERIOR BEARING WALLS SHALL
BE NOT LESS THAN 1X2 HEM-FIR OR BETTER.
4. CONNECTORS FOR WOOD FRAMING SHALL BE GALVANIZED METAL OR
BLACK METAL AS MANUFACTURED OR AS CALLED FOR IN THE PLANS
AND BE OF A DESIGN SUITABLE FOR THE LOADS AND USE INTENDED.
REFER TO THE JOINT REINFORCEMENT SCHEDULE FOR PRINCIPLE CON-
NECTIONS.


These drawings, as instruments of service, are the sole property of the architect, and may not be used, copied or reproduced in whole or in part for use on or incorporated within any other job without specific and individual authorization by the architect.

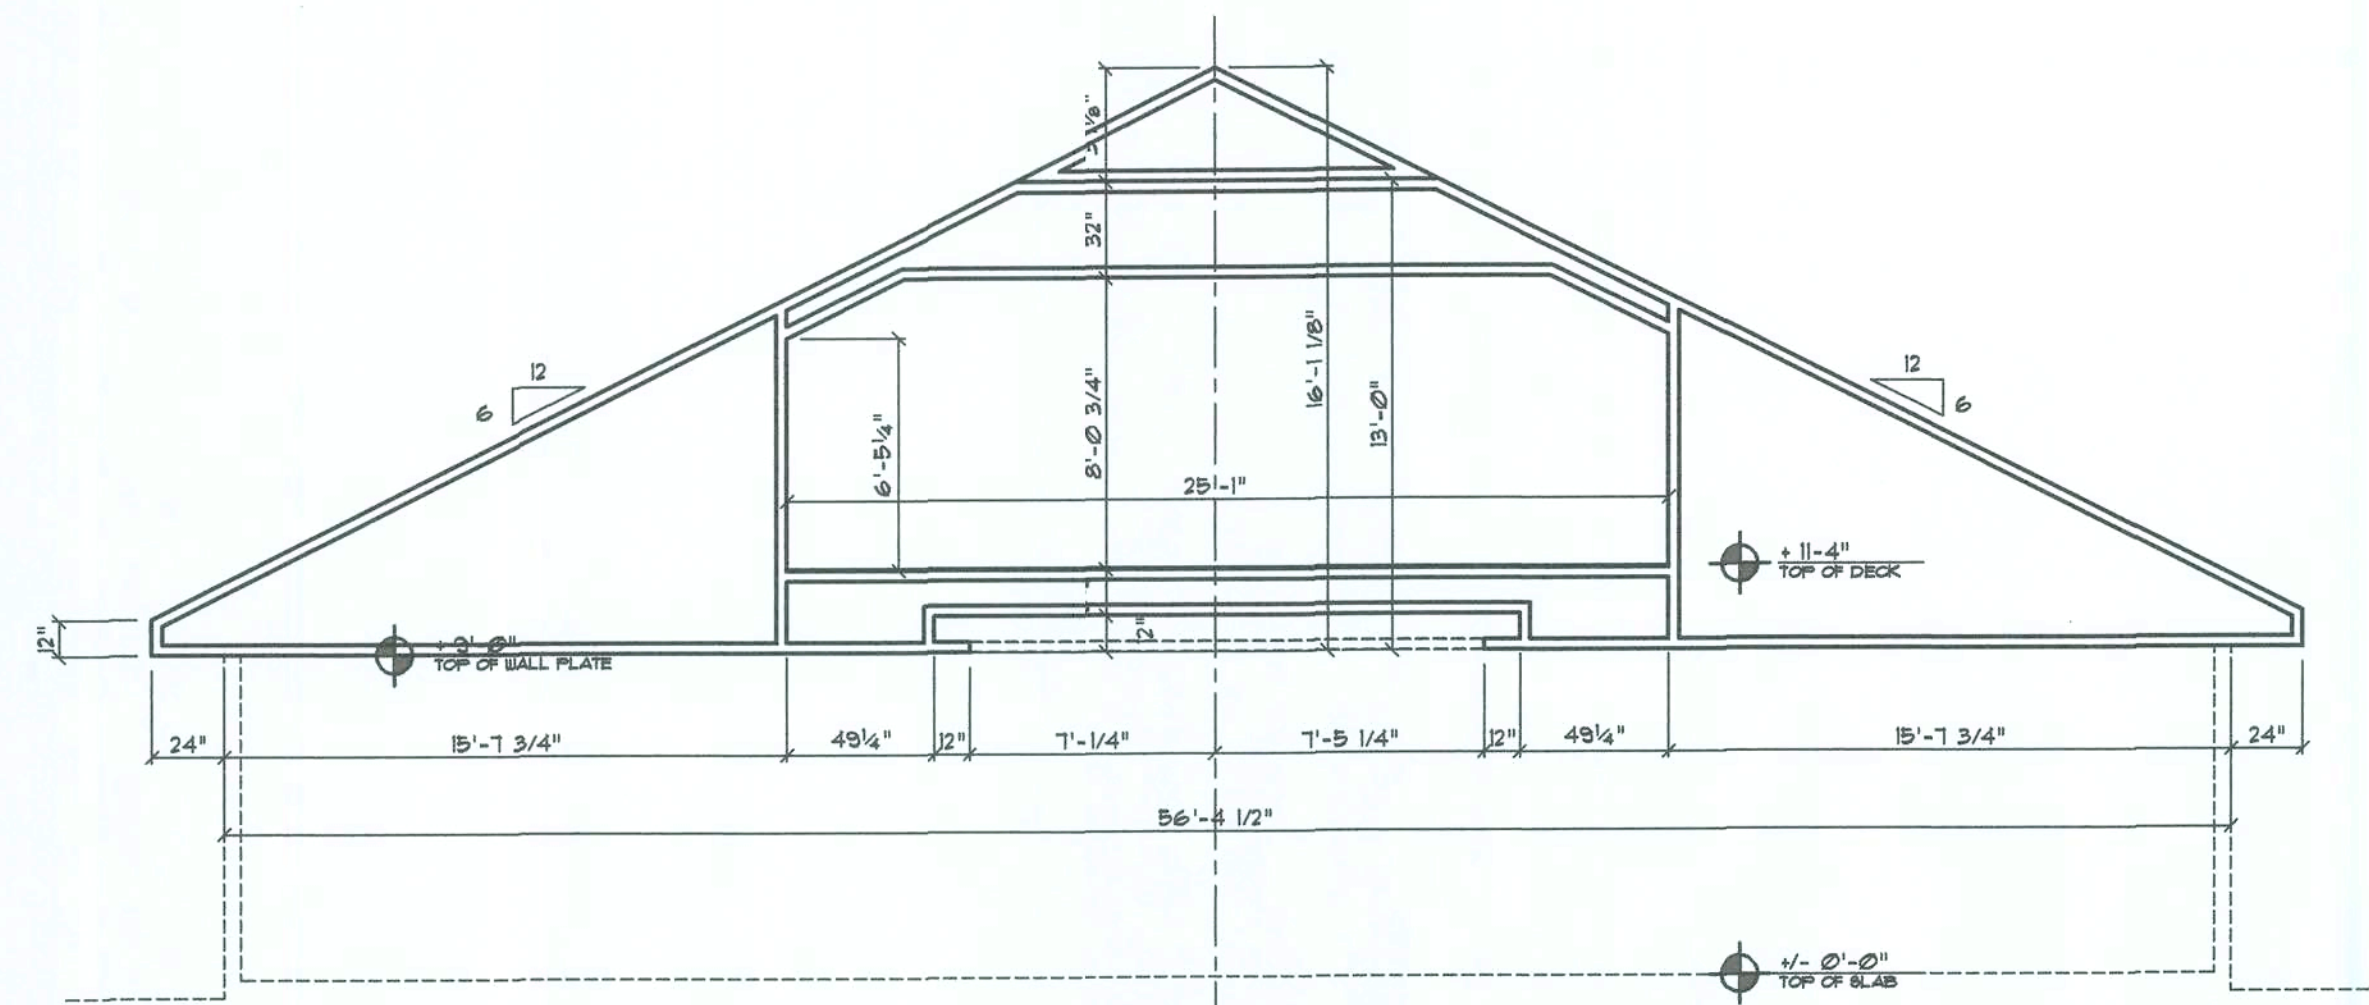


PROFILE @ MEETING ROOM / LIVING AREA
SCALE: 3/16" = 1'-0" TR-1 / TR-2

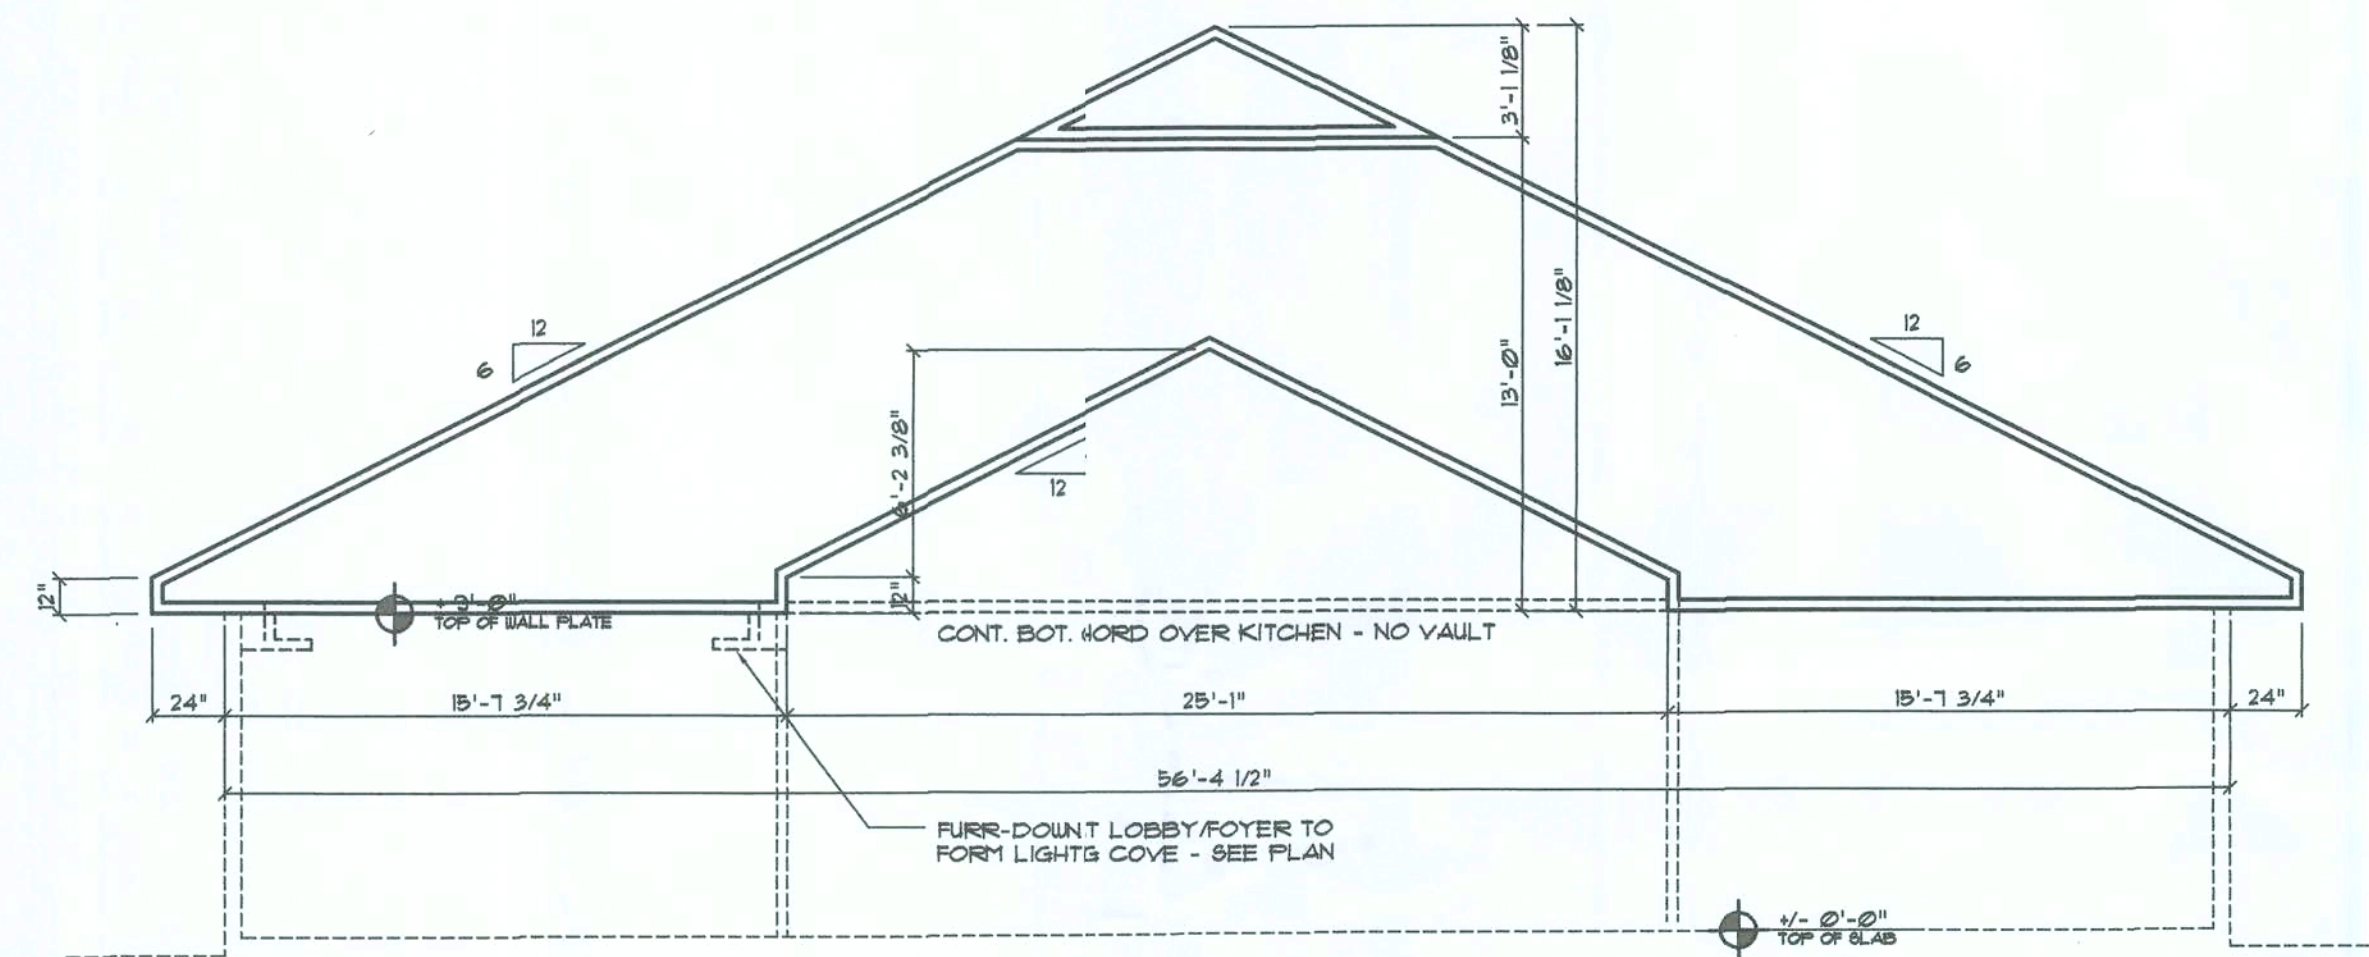


PROFILE @ DINING ROOM / KITCHEN
SCALE: 3/16" = 1'-0" TR-3 / TR-4

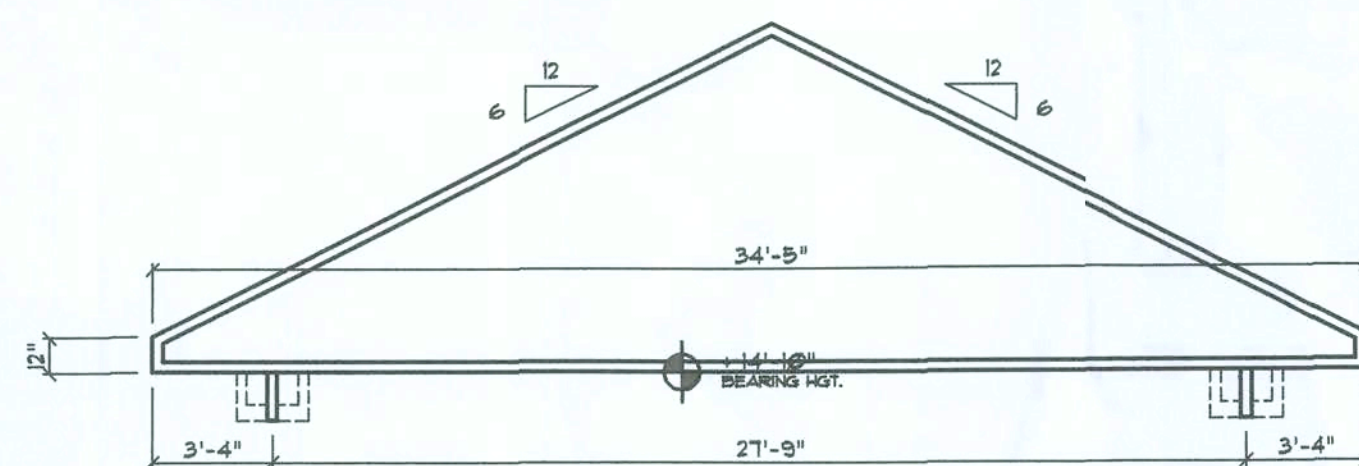


PROFILE @ ENTRY CANOPY
SCALE: 3/16" = 1'-0" TR-9

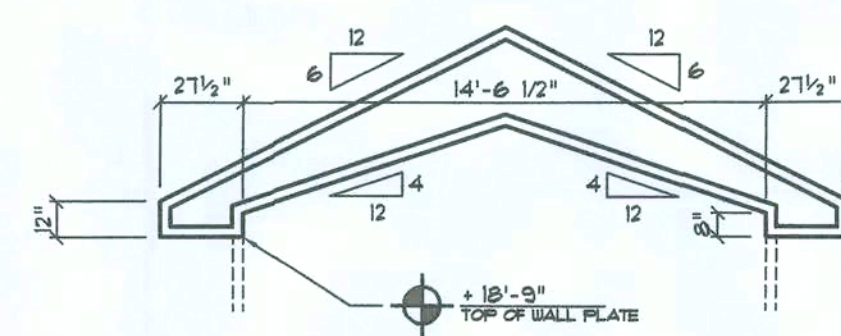


PROFILE @ DORMER
SCALE: 3/16" = 1'-0" TR-10

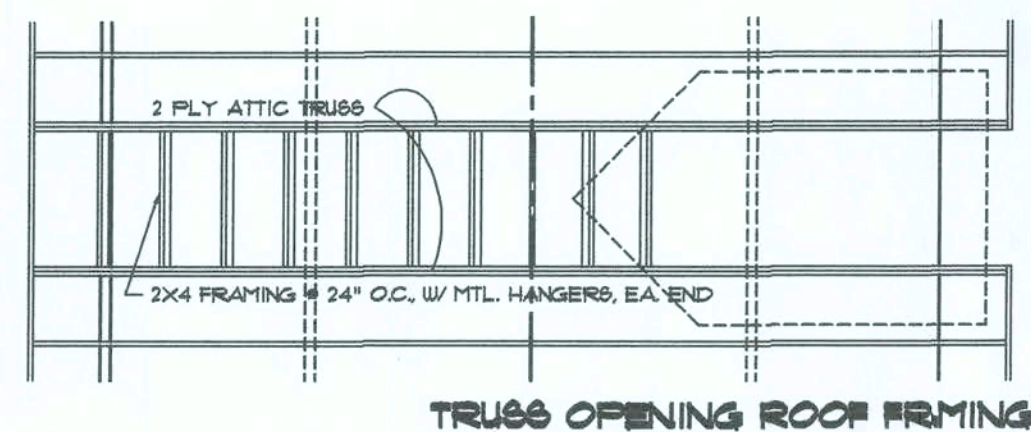


TRUSS OPENING ROOF FRAMING

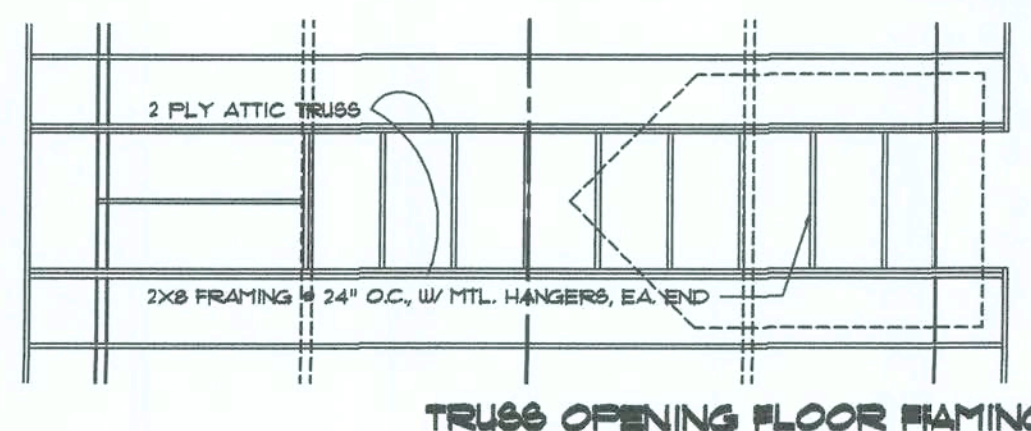


TRUSS OPENING FLOOR FRAMING

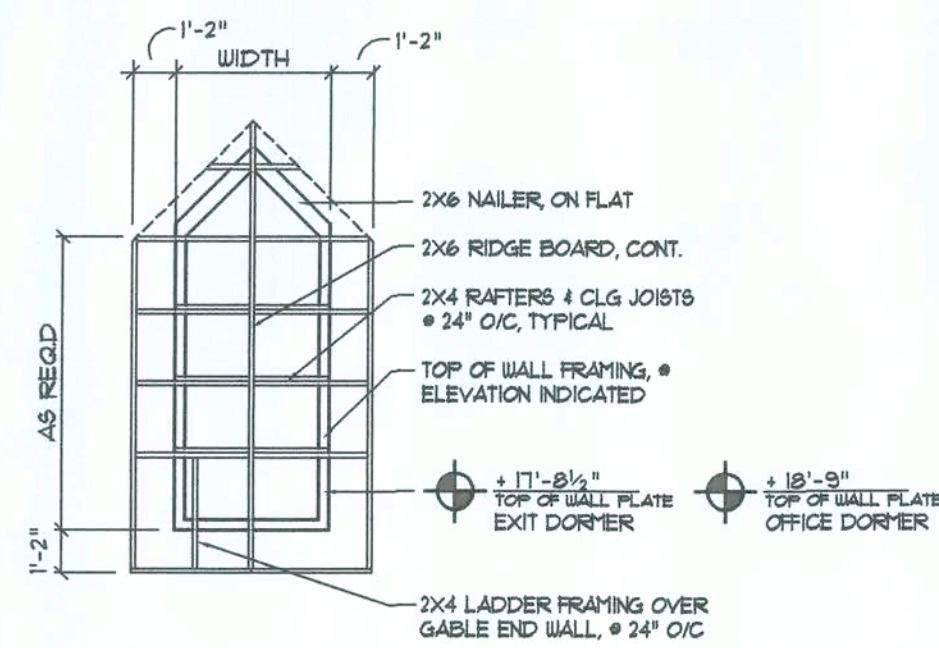


Dormer DETAIL
SCALE: 3/16" = 1'-0"

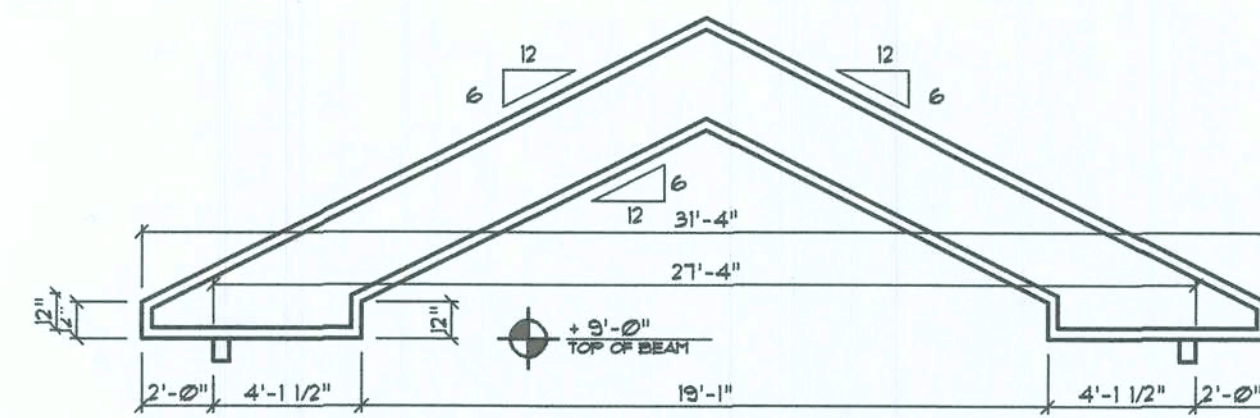

PROFILE @ PAVILLION
SCALE: 3/16" = 1'-0" TR-8

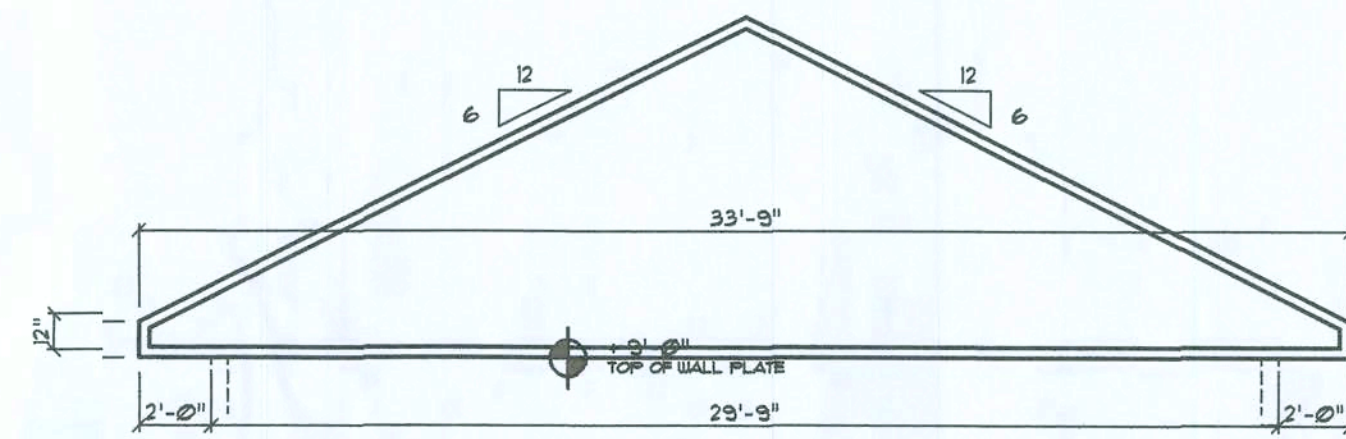

PROFILE @ PAVILLION
SCALE: 3/16" = 1'-0" TR-7

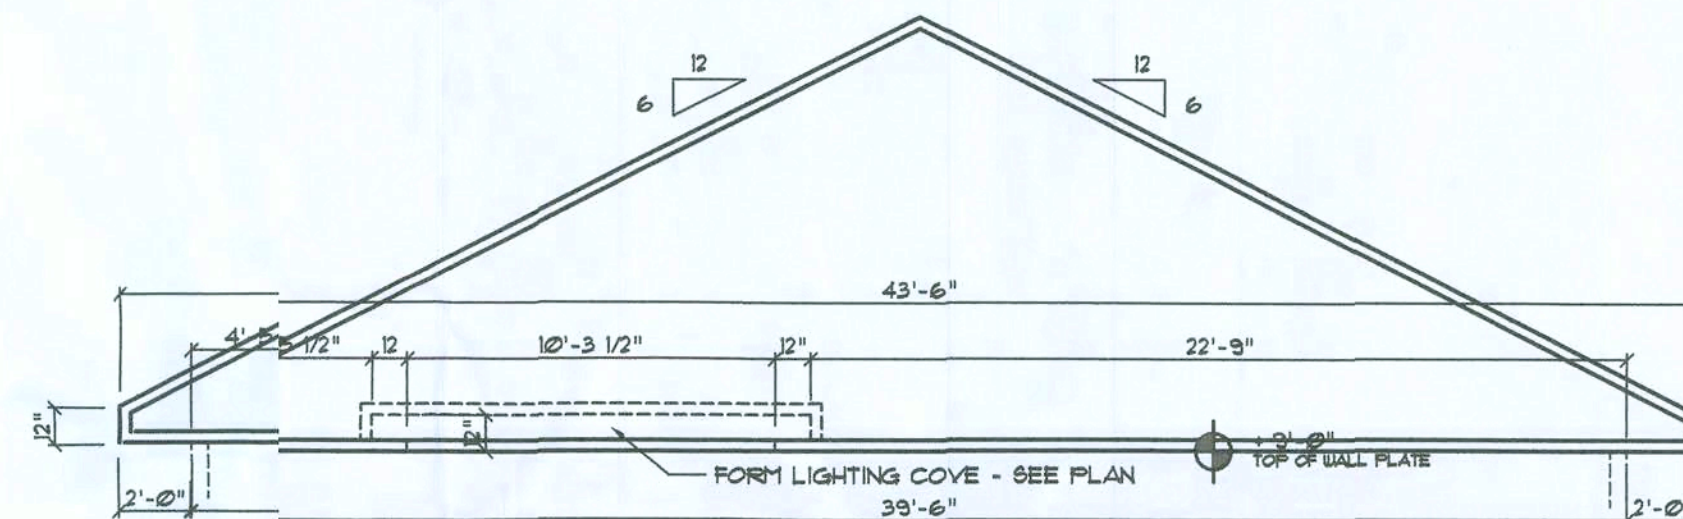

PROFILE @ FAMILY ROOM
SCALE: 3/16" = 1'-0" TR-5 / TR-6

GENERAL TRUSS NOTES:

- TRUSSES SHALL BE DESIGNED BY A LICENSED ENGINEER AND IN ACCORDANCE WITH THE REQUIREMENTS OF THE NATIONAL TRUSS PRODUCTS ASSOCIATION (NTPA) FOR "WITNESS RATED LUMBER AND ITS CONNECTIONS" LATEST EDITION. THE TRUSS ENGINEER SHALL BE RESPONSIBLE FOR THE DESIGN OF THE TRUSS AND THE CONNECTIONS. THE TRUSS ENGINEER SHALL BE RESPONSIBLE FOR THE DESIGN OF THE TRUSS AND THE CONNECTIONS. THE TRUSS ENGINEER SHALL BE RESPONSIBLE FOR THE DESIGN OF THE TRUSS AND THE CONNECTIONS.
- TRUSS SHOP DRAWINGS SHALL BE SIGNED & SEALED BY THE DESIGNING ENGINEER.
- FOLLOWING DEVELOPMENT OF TRUSS SHOP DRAWINGS, ADJUSTMENTS TO THE ANCHOR REQUIREMENTS MAY BE REQUIRED DEPENDENT ON THE ENGINEERED GRAVITY AND WIND UPLIFT REQUIREMENTS OF TRUSSES OR ORDERS. THE CONTRACTOR SHALL MAKE AVAILABLE A COMPLETE SET OF TRUSS SHOP DRAWINGS TO THE ARCHITECT FOR THE PURPOSE OF REVIEW OF LOADS IMPOSED ON THE BALANCE OF THE STRUCTURE. ANY SUCH REQUIRED CHANGE SHALL BE INCORPORATED INTO THE CONSTRUCTION OF THIS STRUCTURE.


NOTE:
PRIOR TO THE CONSTRUCTION OF THE FOUNDATION, THE CONTRACTOR SHALL COORDINATE ANY INTERIOR BEARING LOCATION CONDITIONS PER THE TRUSS PLAN. ANY INTERIOR BEARING LOCATIONS OR ANY POINT LOADS OF 40 K OR GREATER SHALL BE SUPPORTED VIA A MODIFIED FOUNDATION PLAN. THE CONTRACTOR SHALL MAKE THE ENGINEERED TRUSS SHOP DRAWINGS AVAILABLE TO THE ARCHITECT FOR THE PURPOSE OF REVIEWING SUCH MODIFICATIONS PRIOR TO POURING ANY CONCRETE.

SHOP DRAW COORDINATION: THE TRUSS ANCHOR STRAPS AS INDICATED IN THE CONSTRUCTION DOCUMENTS ARE SUGGESTED STRAPS AND THAT THE TRUSS ENGINEERED SHOP DRAWINGS TAKE PRECEDENCE OVER THAT INDICATED IN THE CONSTRUCTION DOCUMENTS. THE UPLIFT LOADS INDICATED FOR EACH TRUSS IN THE ENGINEERED TRUSS SHOP DRAWINGS MAY BE MATCHED TO STANCO PRODUCT UPLIFT RANGING FOR COMPARABLE UPLIFT CONNECTIONS, AND THAT THE PRODUCTS THAT PROVIDE EQUAL OR GREATER UPLIFT RESISTANCE FOR THE LISTED LOADS MAY BE USED IN LIEU OF THOSE INDICATED IN THE CONSTRUCTION DOCUMENTS OR AS APPROVED BY THE BUILDING OFFICIAL.


THE CONTRACTOR SHALL COORDINATE THE TRUSS TO TRUSS ANCHOR REQUIREMENTS WITH THE TRUSS ENGINEERED SHOP DRAWINGS. SCHE OF THE TRUSS TO TRUSS CONNECTIONS WILL REQUIRE ANCHOR STRAPS IN ADDITION TO TYPICAL WALLS. ANCHOR STRAPS SHALL BE REQUIRED FOR ALL JOINTS WITH AN UPLIFT OR GRAVITY LOAD OF 100 LBS OR GREATER.

PRINCIPLE TRUSS PROFILES


SCALE: 3/16" = 1'-0"

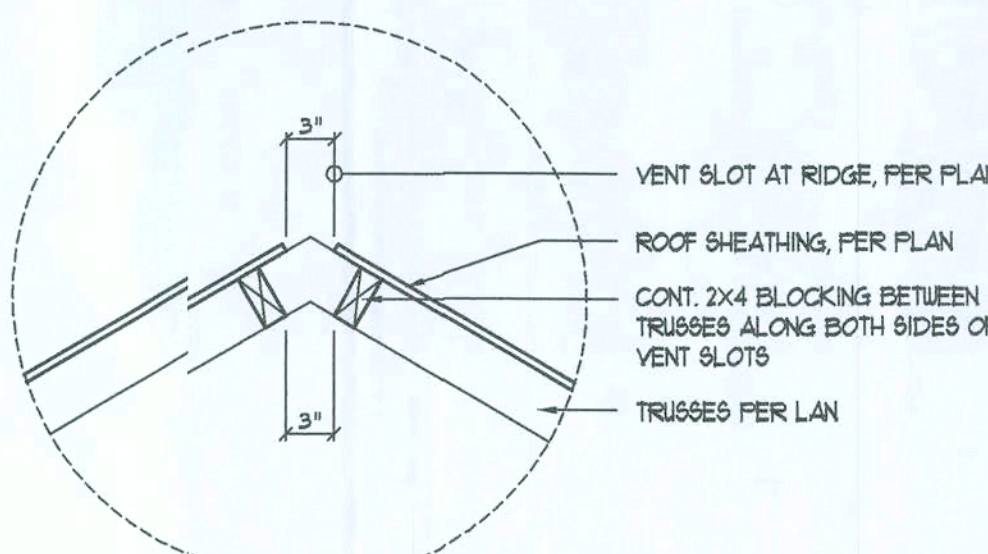


Vent DETAIL
SCALE: 1" = 1'-0"

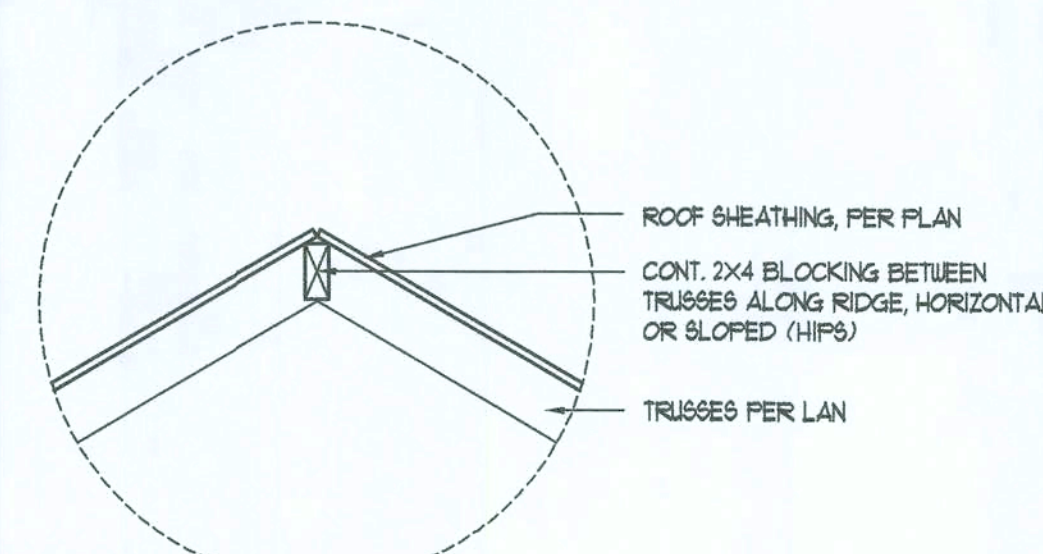

Ridge DETAIL
SCALE: 1" = 1'-0"

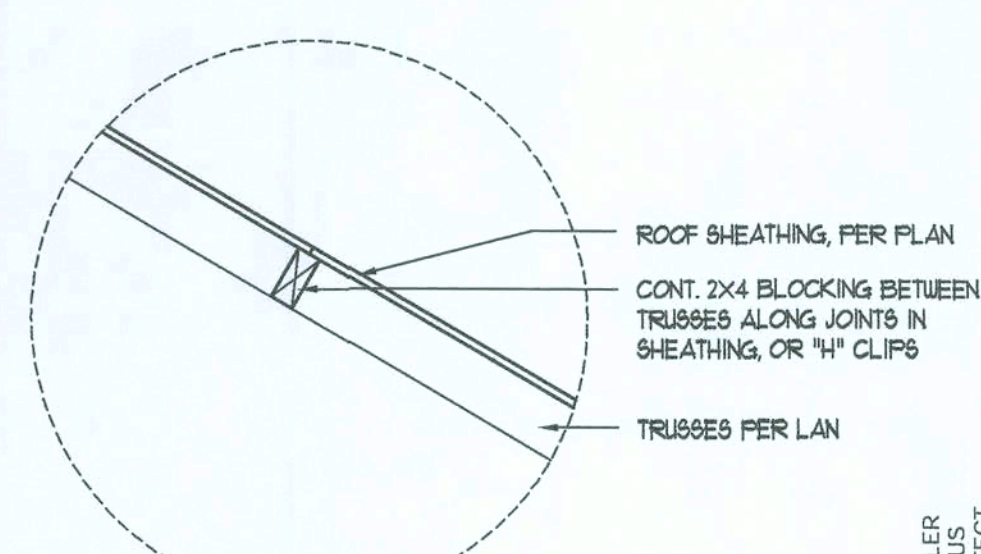


Joint DETAIL
SCALE: 1" = 1'-0"

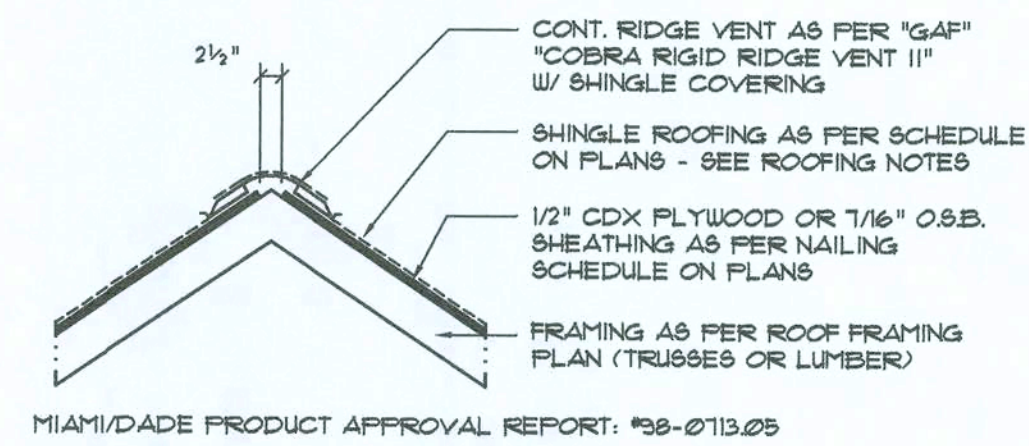

Ridge Vent DETAIL
SCALE: 3/4" = 1'-0"

ROOFING METALS for FLASHING/ROOFING MINIMUM THICKNESS REQUIREMENTS			
MATERIAL	MINIMUM THICKNESS (in.)	GAGE	WEIGHT (oz)
COPPER			16
ALUMINUM	0.024		
STAINLESS STEEL		28	
GALVANIZED STEEL	0.019	26 (ZINC COATED G30)	
ZINC ALLOY LEAD PAINTED TERNE	0.021		40 20

Roofing/Flashing DETS.
SCALE: NONE

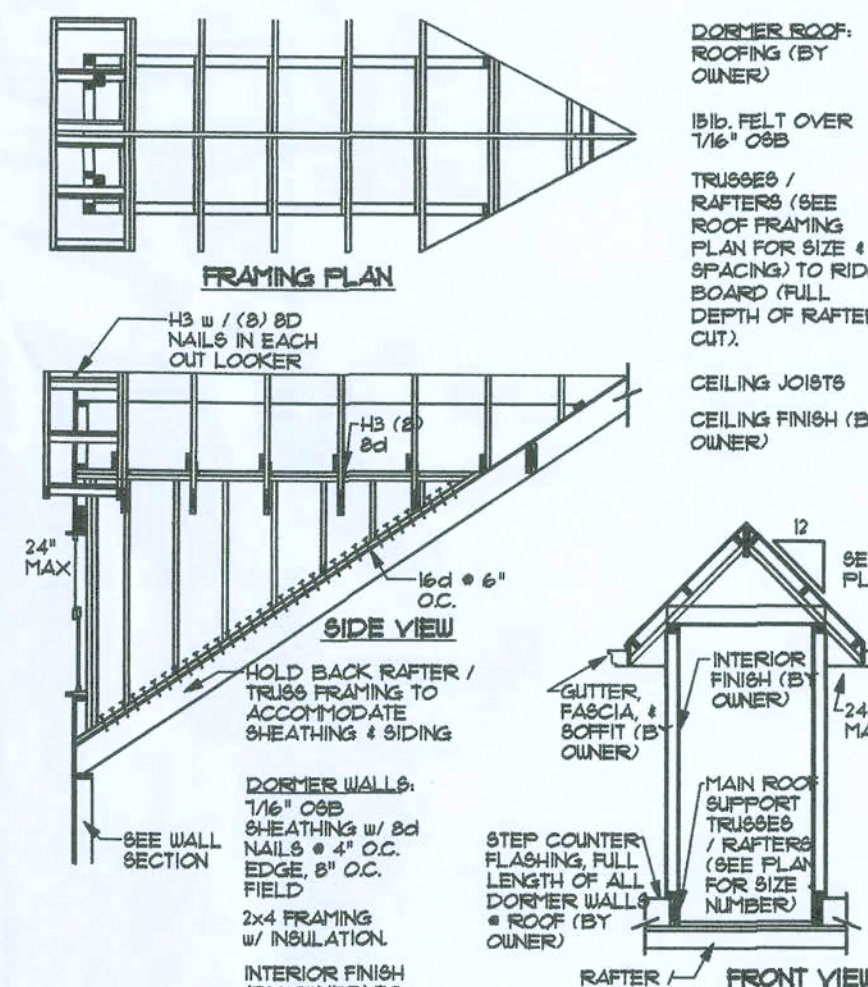

Dormer Framing DET.
SCALE: NTS.

AREA OF ATTIC	REQD LF. AREA OF VENT	NET FREE AREA OF INTAKE
1600 SF	20 LF	410 SQ.IN.
1800 SF	24 LF	490 SQ.IN.
2200 SF	28 LF	570 SQ.IN.
2600 SF	32 LF	650 SQ.IN.
2800 SF	36 LF	730 SQ.IN.
3000 SF	40 LF	810 SQ.IN.
3600 SF	44 LF	900 SQ.IN.

REVISOR:
02 SEP 2020

Copyright 2020
N.P. Gesler, Architect

DRAWN:
118

ASSISTED LIVING FACILITY for
SMITH - GORENGEN
LAKE CITY, COLUMBIA COUNTY, FLORIDA
ROOF PLAN

Celebrating
48 Years of Service
1972 - 2020
N.P. Gesler, Architect
ARCHITECT
N.C.A.R.B. - 4355

NICHOLAS PAUL GIESLER
ARCHITECT
N.C.A.R.B. - 4355


DATE:
18 AUG 2020

CONTRACT:
2K1040

SHEET:
5.5


5 OF 6

AR000005

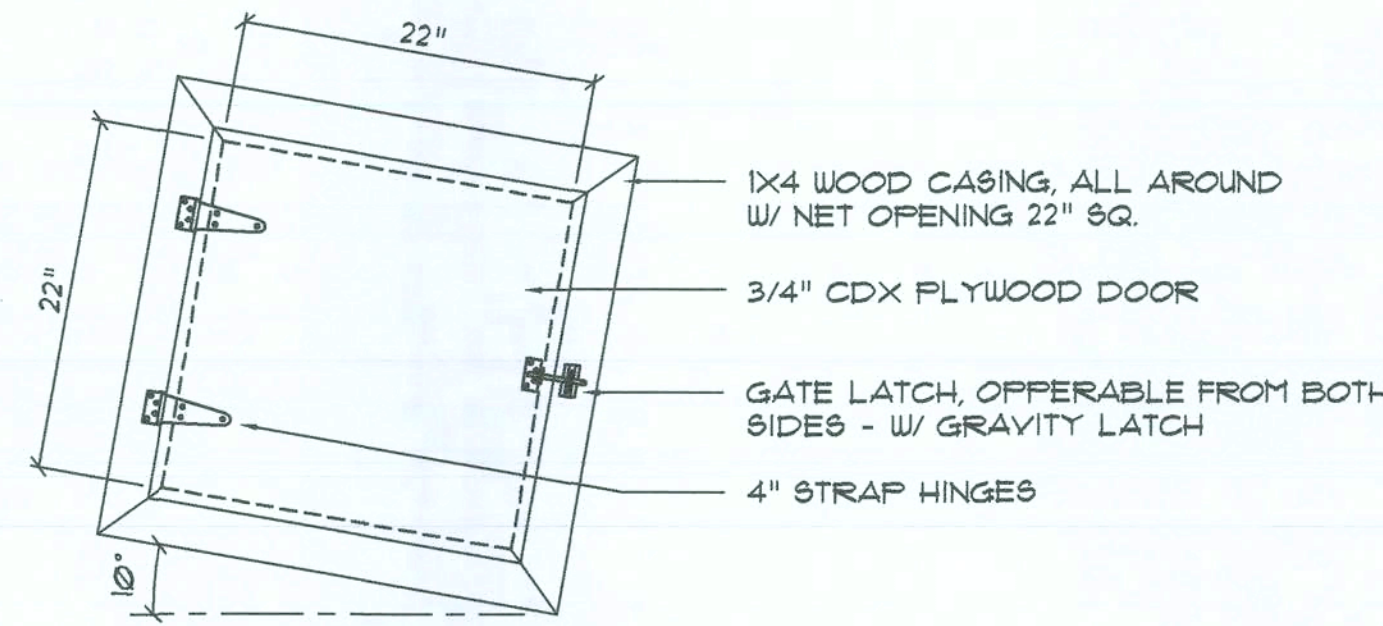


Self-Closing, Smoke Division Wall, Scuttle DET.

SCALE: 1" = 1'-0"

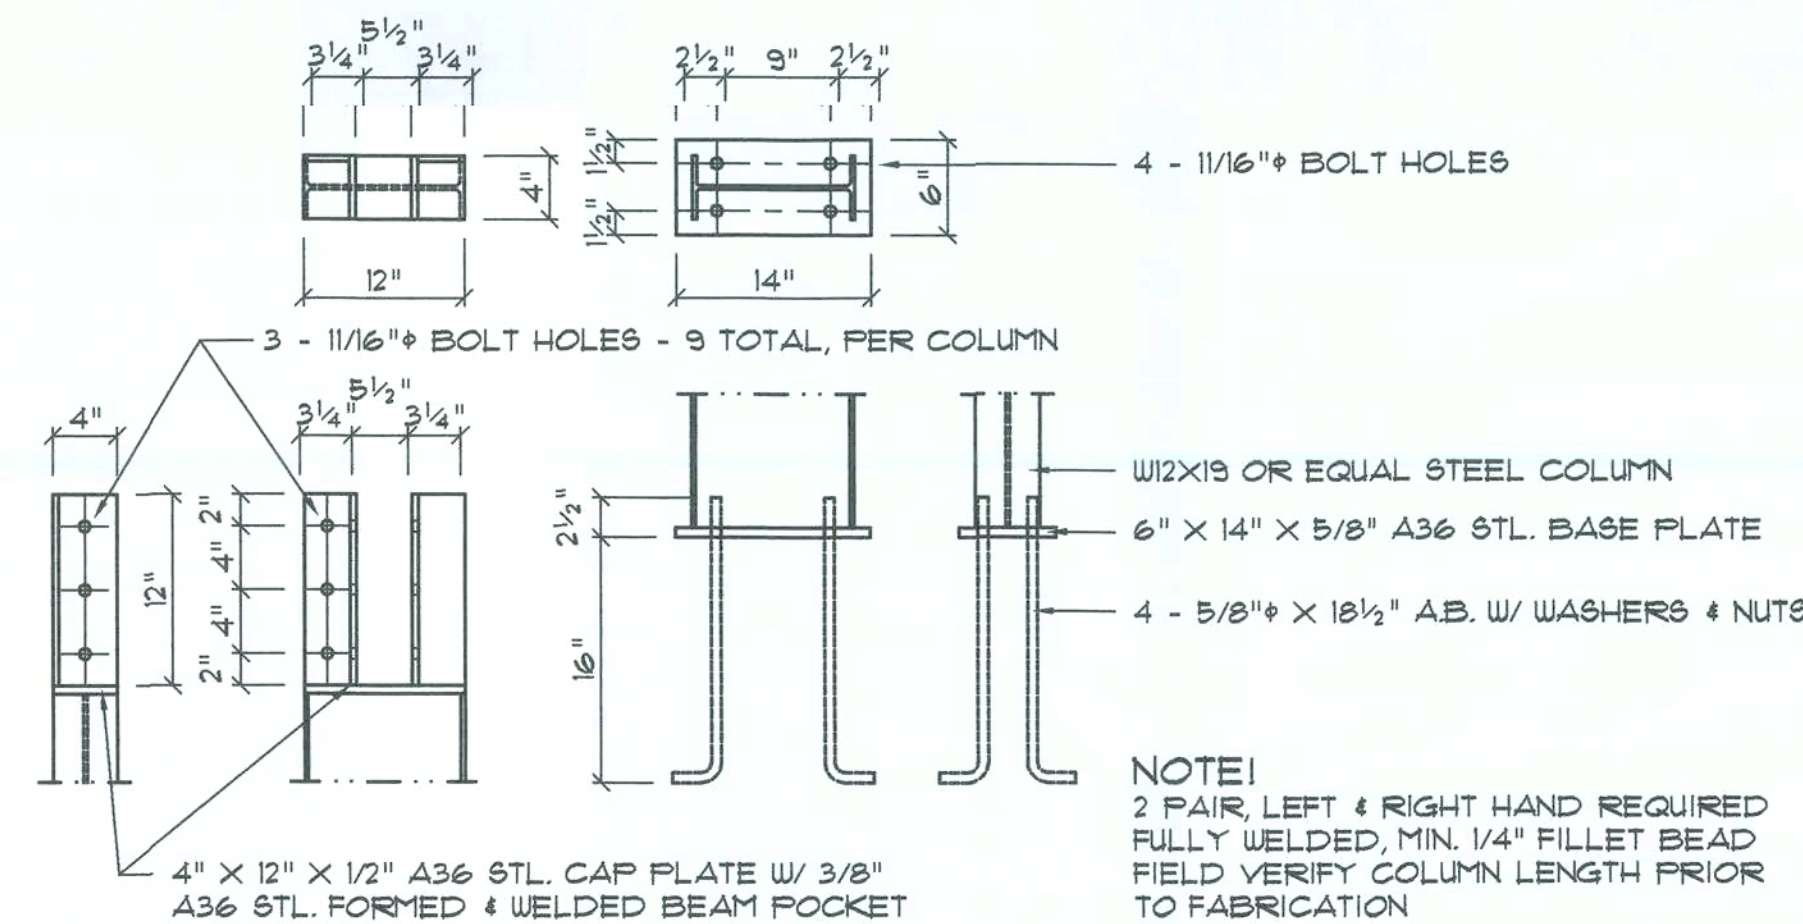


Steel Column DET.

SCALE: N.T.S.

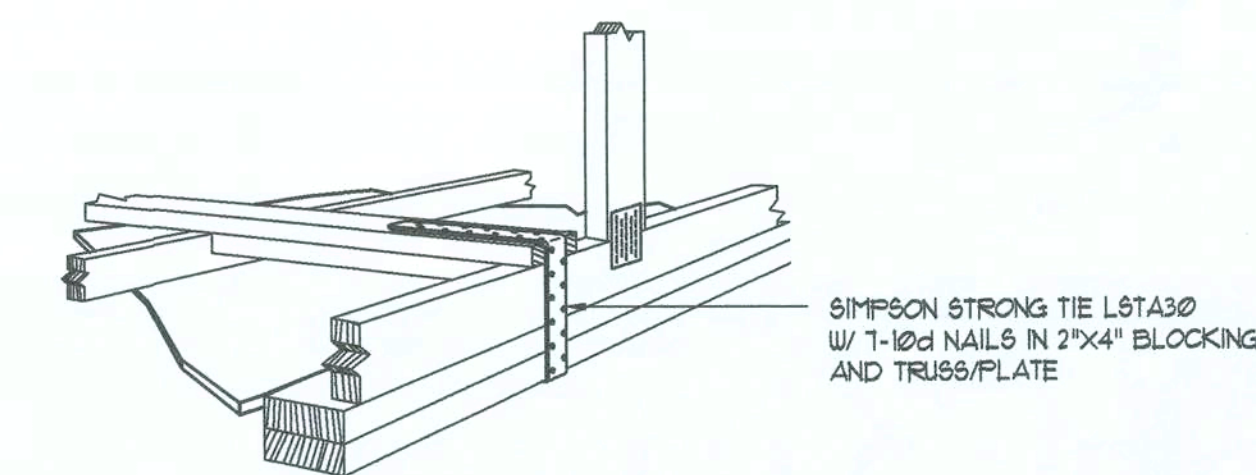

Gable End Gypsum Diaphragm


SCALE: NONE

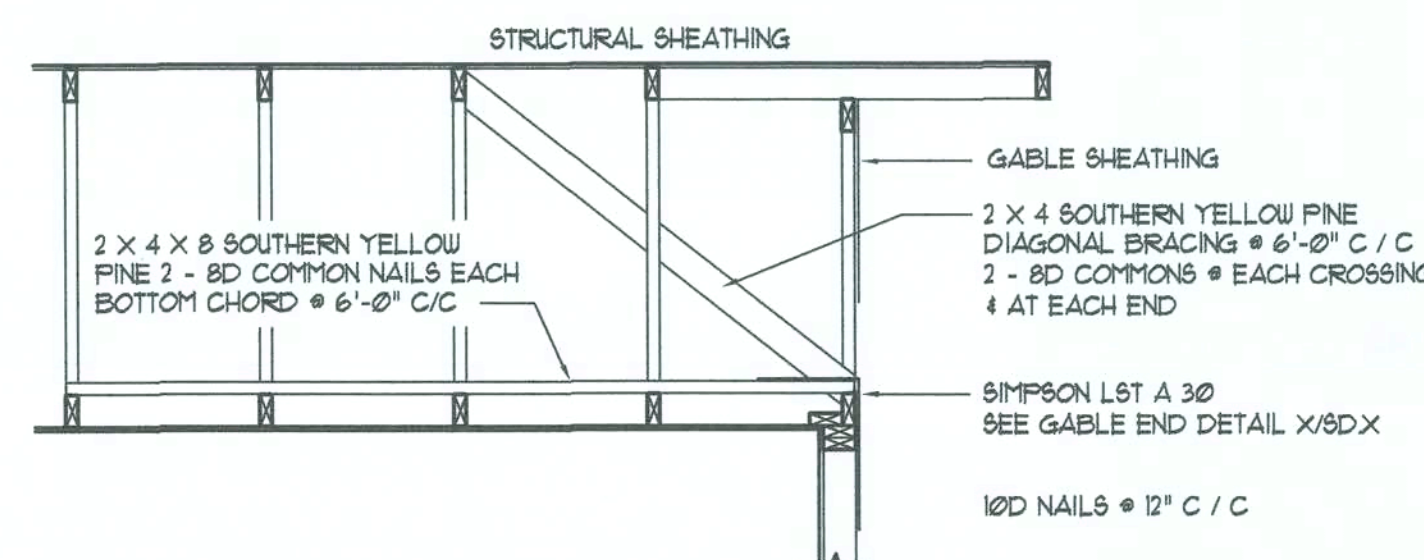

End Wall Bracing for Ceiling Diaphragm

NTS (ALTERNATIVE TO BALLOON FRAMING)
NOTE: ALL WOOD TO BE NUMBER 2 GRADE SOUTHERN YELLOW PINE


ROOF SHEATHING FASTENINGS			
NAILING ZONE	SHEATHING TYPE	FASTENER	SPACING
1		6d RING SHANK OR 8d HOT DIPPED GALVANIZED BOX NAILS	6 in. o.c. EDGE 12 in. o.c. FIELD
2	1/4" OSB OR 15/32 CDX		6 in. o.c. EDGE 6 in. o.c. FIELD
3			4 in. o.c. GABLE ENDWALL OR GABLE TRUSS 6 in. o.c. EDGE 6 in. o.c. FIELD

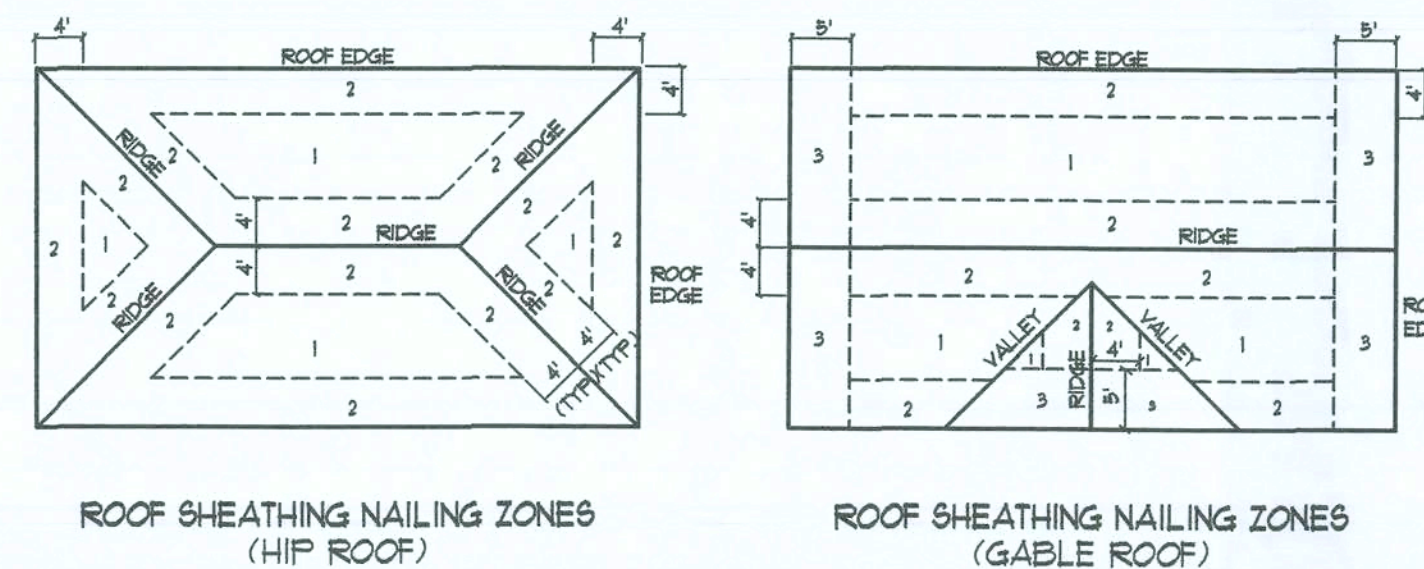

Roof Nail Pattern DET.


SCALE: NONE

HEADERS SUPPORTING:		HEADER SPANS FOR EXTERIOR BEARING WALLS					
		BUILDING WIDTH (FT)					
		20'		28'		36'	
HEADERS SUPPORTING:	HEADER SIZE	SPAN	* JACKS	SPAN	* JACKS	SPAN	* JACKS
ROOF, CEILING	2-2x4	3'-6"	1	3'-2"	1	2'-10"	1
	2-2x6	5'-5"	1	4'-8"	1	4'-2"	1
	2-2x8	6'-10"	1	5'-11"	2	5'-4"	1
	2-2x10	8'-5"	2	7'-3"	2	6'-6"	2
	2-2x12	9'-9"	2	8'-5"	2	7'-6"	2
	3-2x8	8'-4"	1	7'-5"	1	6'-8"	1
	3-2x10	10'-6"	1	9'-1"	2	8'-2"	1
	3-2x12	12'-2"	2	10'-7"	2	9'-5"	2
	4-2x8	9'-2"	1	8'-4"	1	9'-2"	1
	4-2x10	11'-8"	1	10'-6"	1	9'-5"	1
	4-2x12	14'-1"	1	12'-2"	2	10'-11"	1

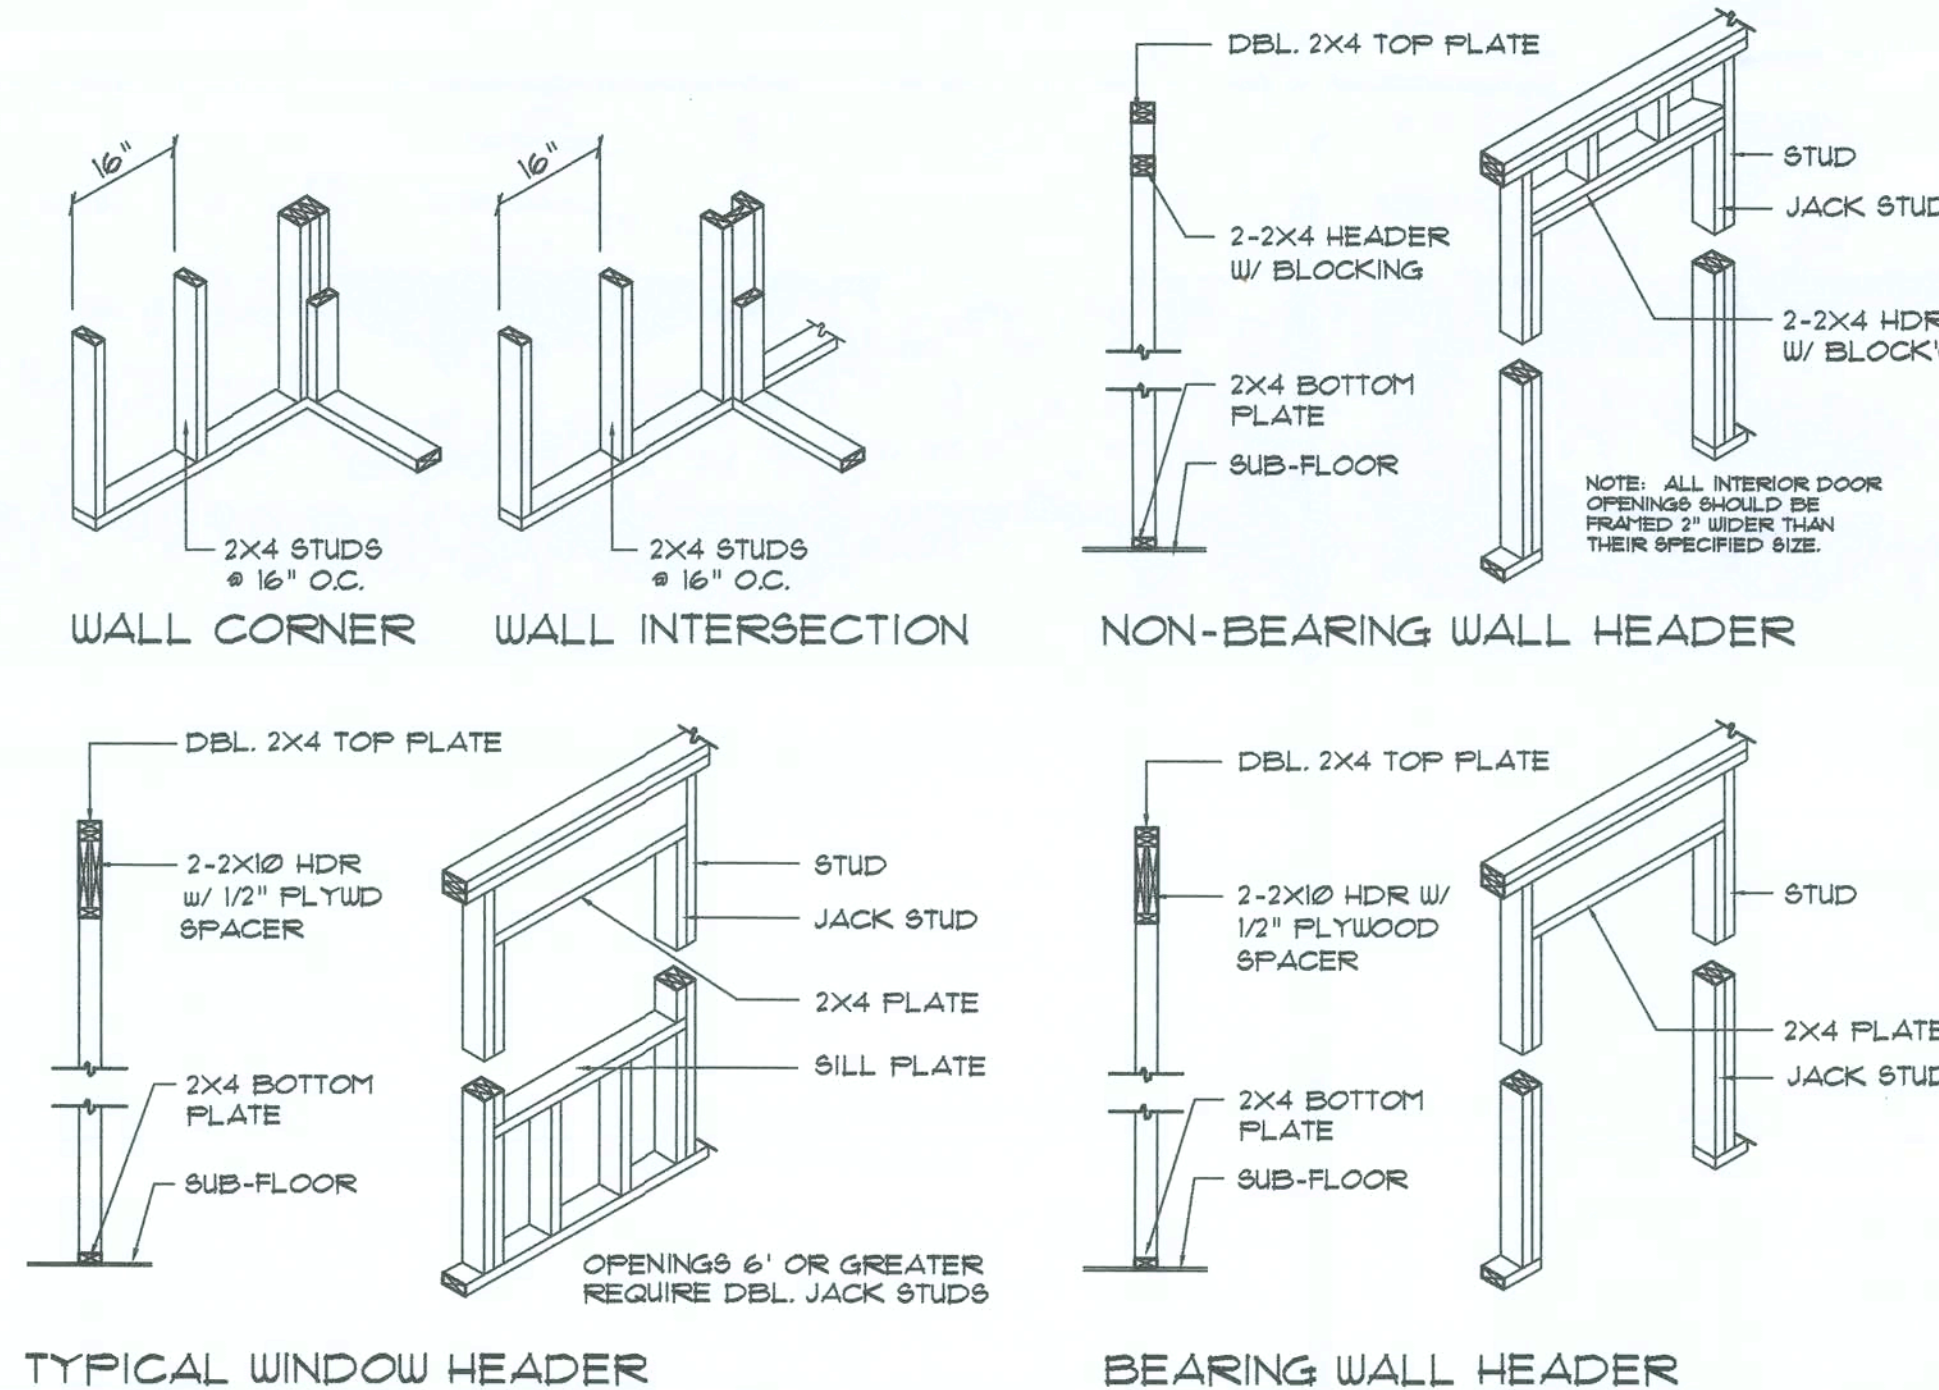


Wall Framing/Header DETAILS

SCALE: NONE

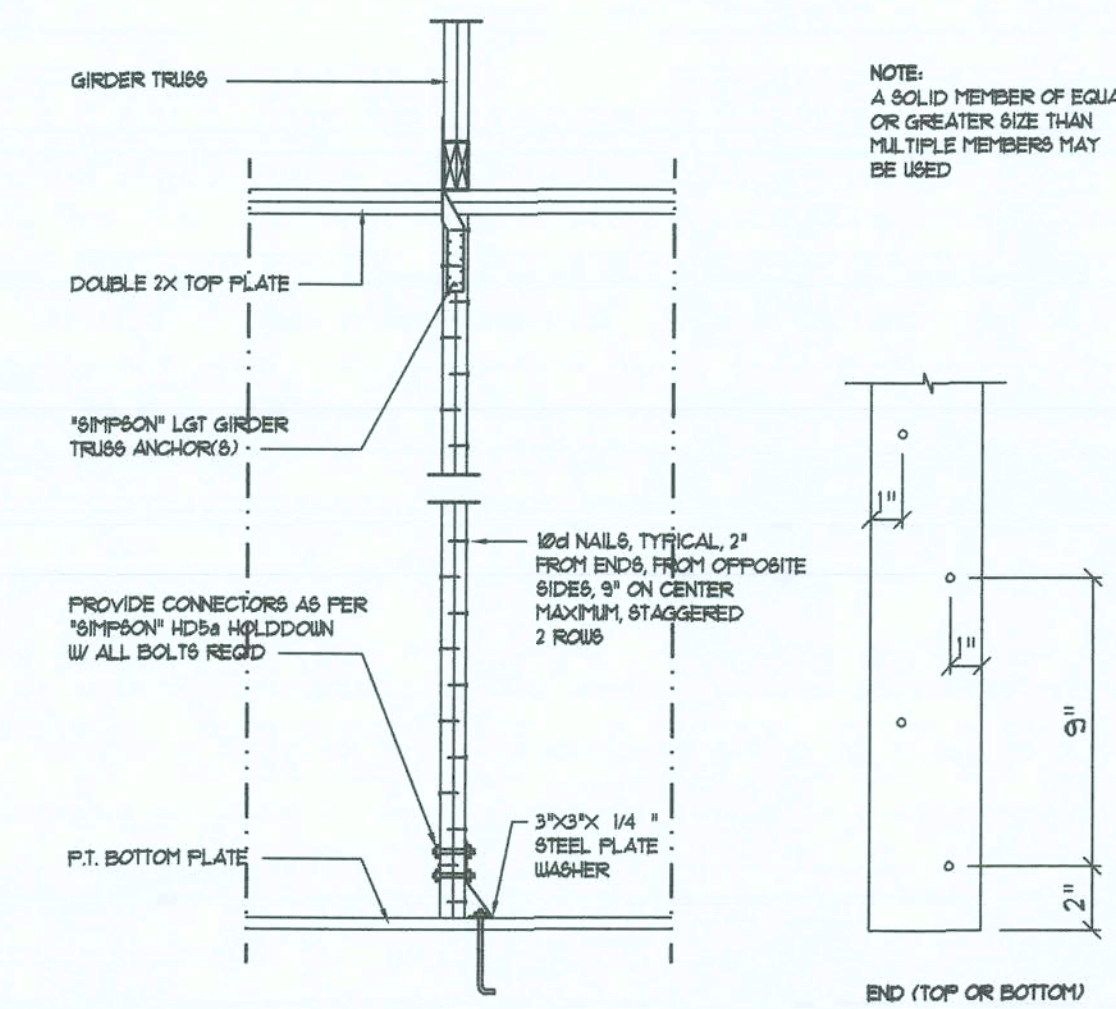

Girder Truss Column DET.

SCALE: 1/2" = 1'-0"

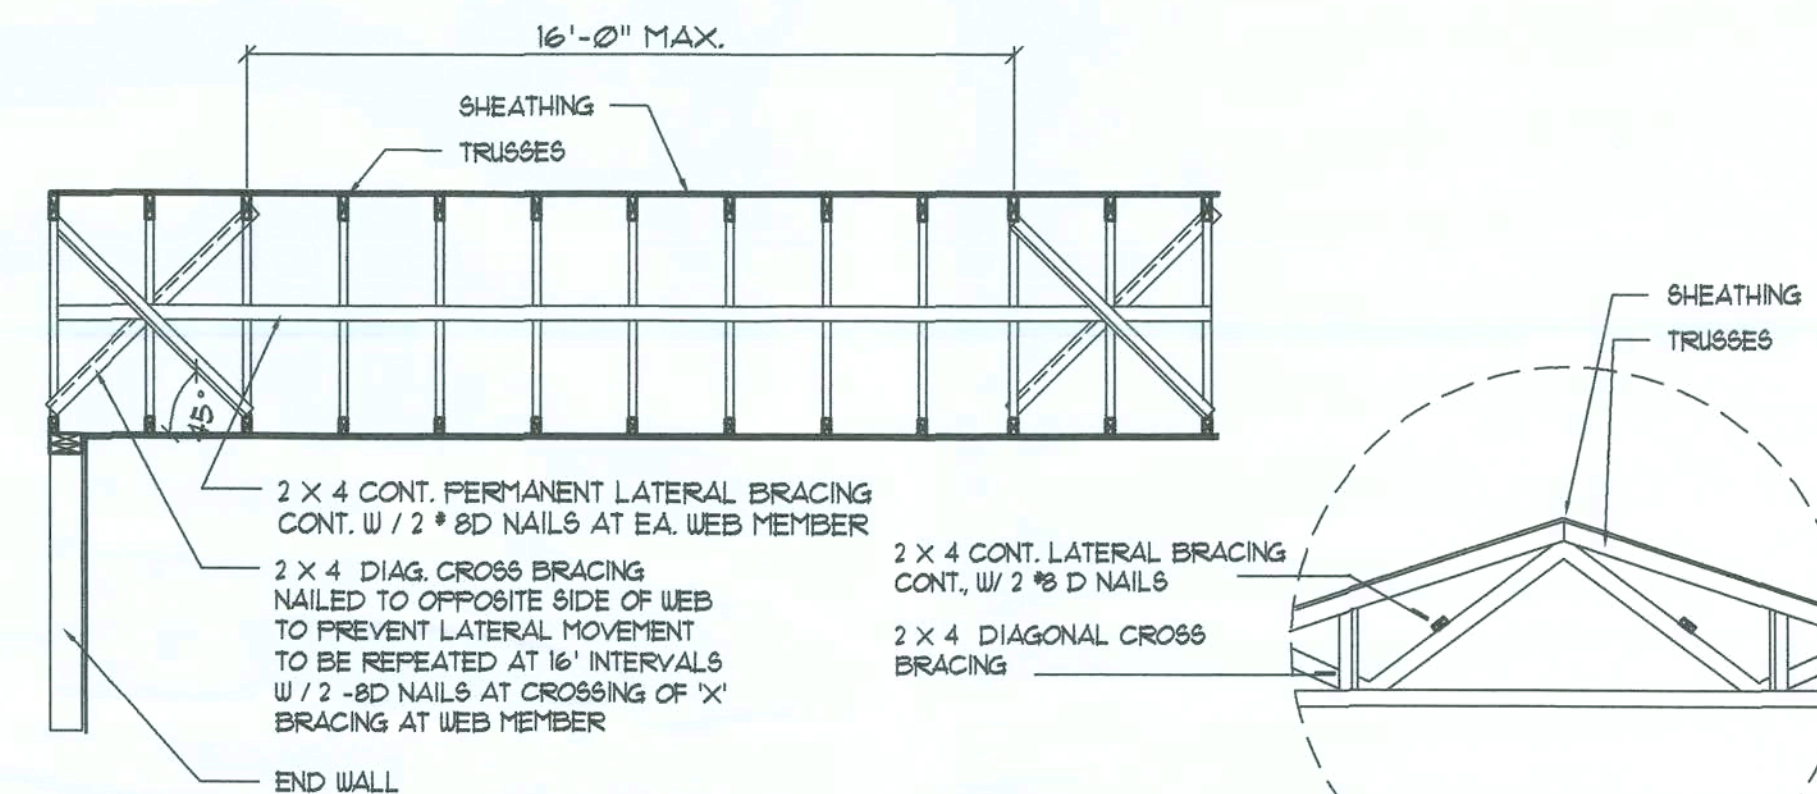


Typ. Permanent Truss Bracing Dia.

NTS
NOTE: ALL WOOD TO BE NUMBER 2 GRADE SOUTHERN YELLOW PINE

Truss Bracing DETAILS

SCALE: AS NOTED

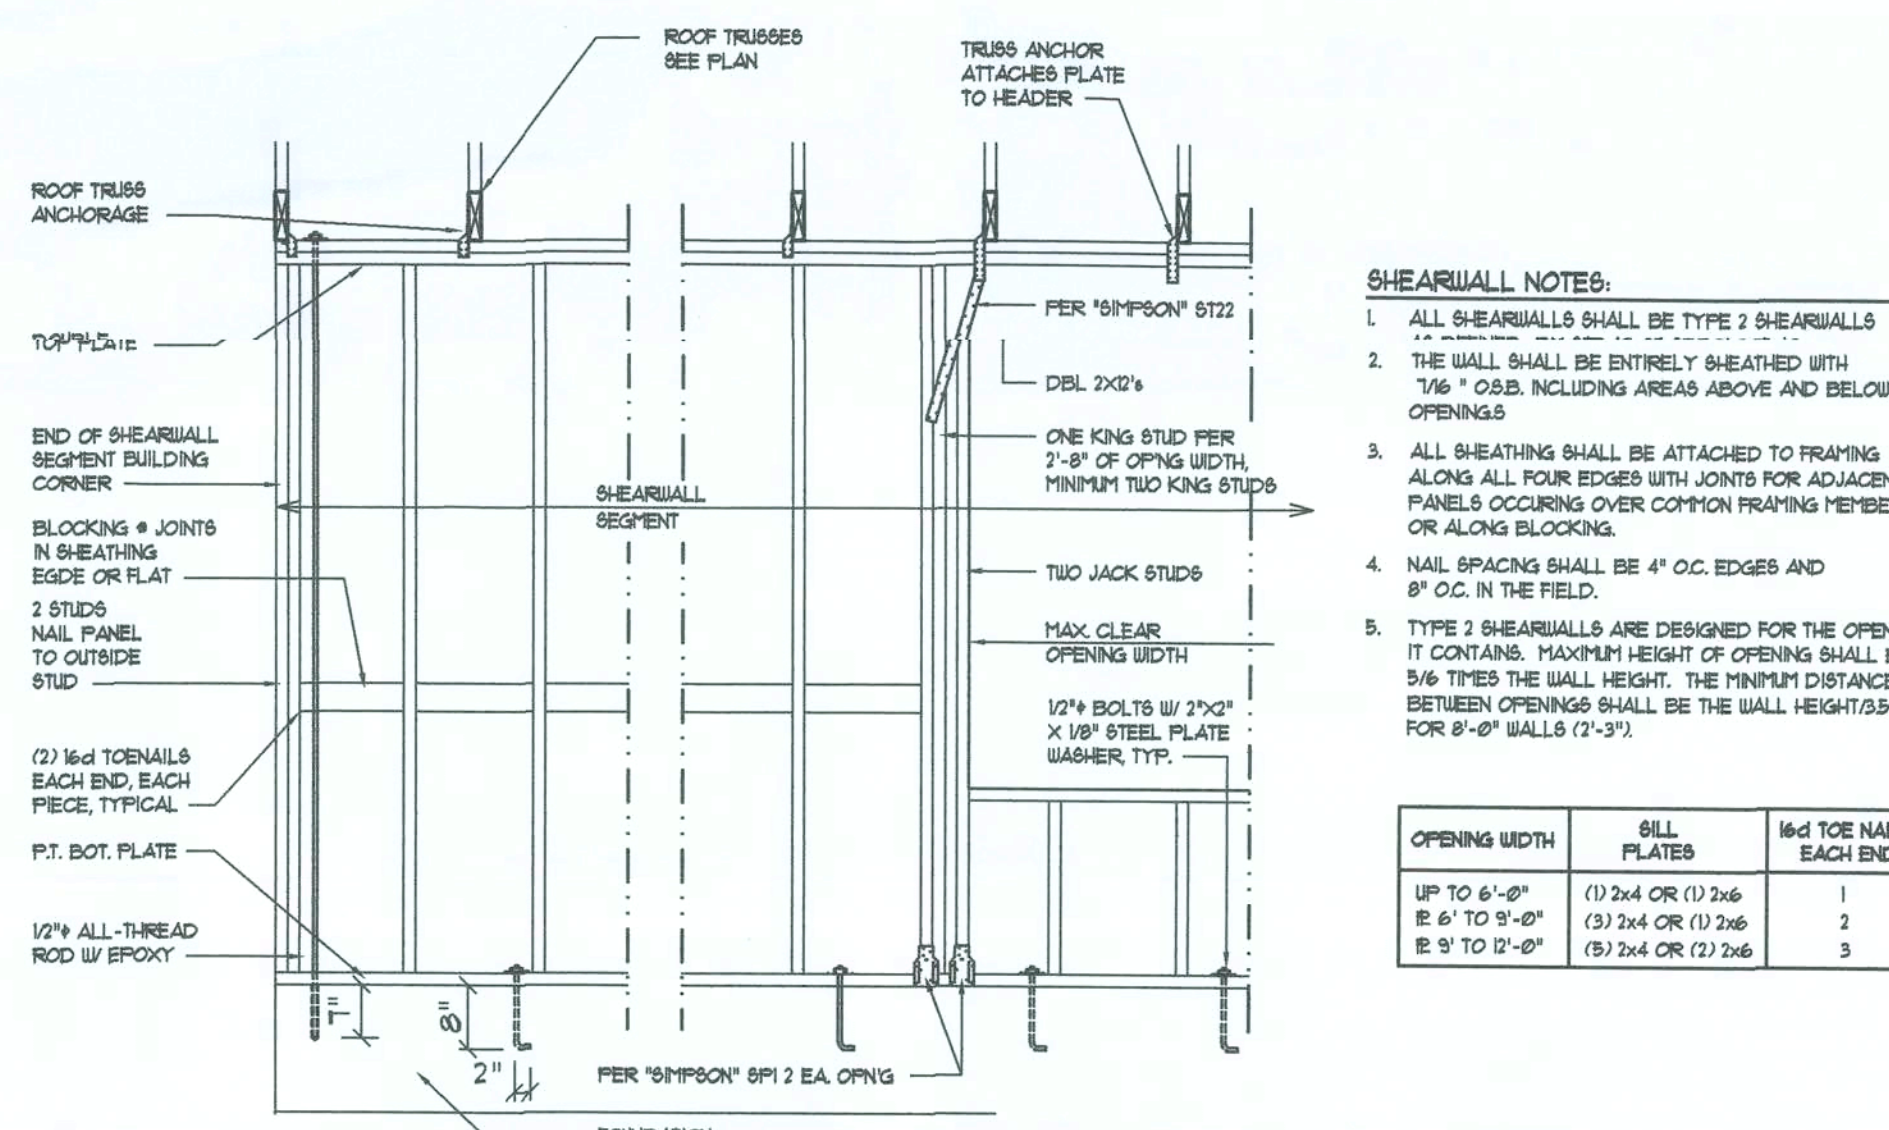

- SHEARWALL NOTES:**
- ALL SHEARWALLS SHALL BE TYPE 2 SHEARWALLS.
 - THE WALL SHALL BE ENTIRELY SHEATHED WITH 7/16" OSB, INCLUDING AREAS ABOVE AND BELOW OPENINGS.
 - ALL SHEATHING SHALL BE ATTACHED TO FRAMING ALONG ALL FOUR EDGES WITH JOINTS FOR ADJACENT PANELS OCCURRING OVER COMMON FRAMING MEMBERS OR ALONG BLOCKING.
 - NAIL SPACING SHALL BE 4" O.C. EDGES AND 8" O.C. IN THE FIELD.
 - TYPE 2 SHEARWALLS ARE DESIGNED FOR THE OPENING IT CONTAINS. MAXIMUM HEIGHT OF OPENING SHALL BE 5/6 TIMES THE WALL HEIGHT. THE MINIMUM DISTANCE BETWEEN OPENINGS SHALL BE THE WALL HEIGHTS FOR 8'-0" WALLS (2'-3").

OPENING WIDTH	SILL PLATES	16D TOE NAILS EACH END
UP TO 6'-0"	(1) 2x4 OR (1) 2x6	1
6'-0" TO 8'-0"	(3) 2x4 OR (1) 2x6	2
8'-0" TO 12'-0"	(5) 2x4 OR (2) 2x6	3

Shear Wall DETAILS

SCALE: NONE

REVISION:

Copyright 2020
N.P. Gesler, Architect

DRAWN:

11/8

ASSISTED LIVING FACILITY for
GRANDE CYPRESS
LAKE CITY, COLUMBIA COUNTY, FLORIDA
STRUCTURAL DETAILS

Celebrating 48 Years of Service
1972 - 2020
N.P. Gesler, Architect
AR0007005

NICHOLAS GESLER ARCHITECT
N.C.A.P.B. Certified
1756 N. Brown Rd.
386-356-4353

DATE:

18 AUG 2020

CONTRACT:

2K2040

SHEET:


5.6

6 OF 6

AR0007005

Digitally signed by N.P. Gesler
DN: cn = N. P. Gesler, c = US
o = AR0007005, ou = ARCHITECT
Date: 2020.08.18 16:24:03 -05'00'

These drawings, or instruments of service, are the sole property of the architect, and may not be used, copied or reproduced in whole or in part for use on or incorporated within any other job without specific and individual authorization by the architect.

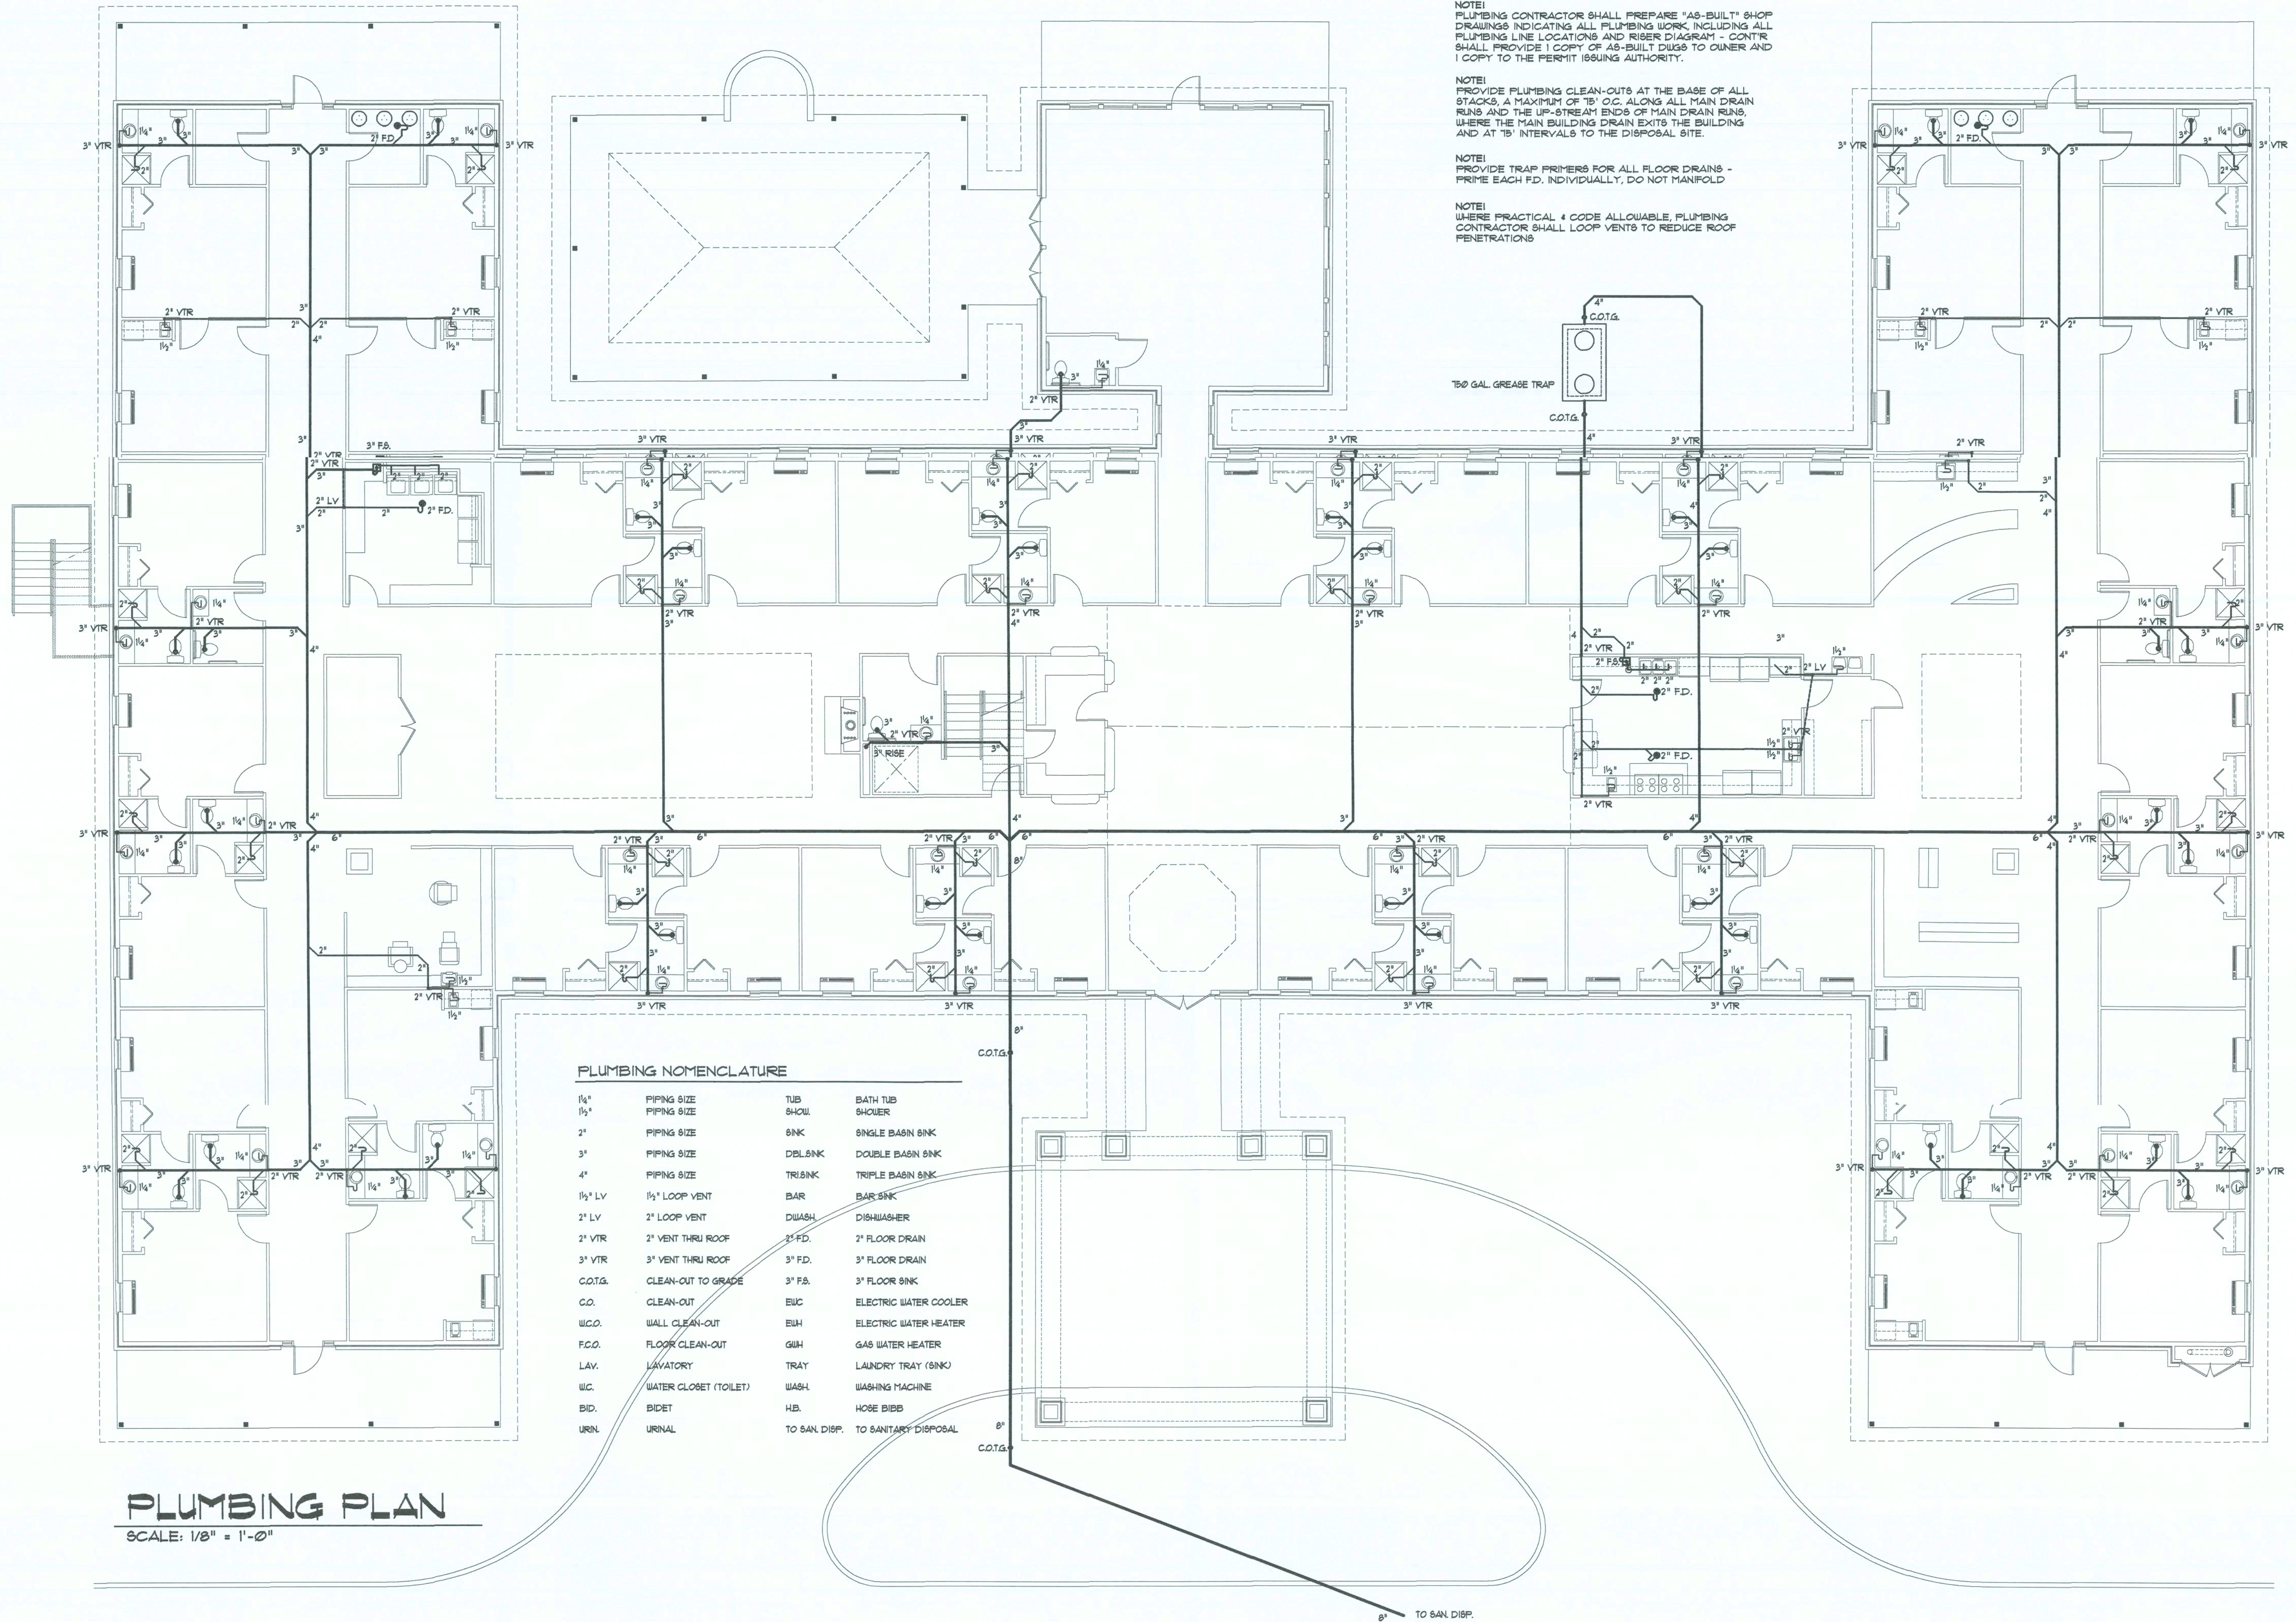

PLUMBING PLAN
SCALE: 1/8" = 1'-0"

PLUMBING NOMENCLATURE

1/4"	PIPING SIZE	TUB	BATH TUB
1/2"	PIPING SIZE	SHOW.	SHOWER
2"	PIPING SIZE	SINK	SINGLE BASIN SINK
3"	PIPING SIZE	DBL.SINK	DOUBLE BASIN SINK
4"	PIPING SIZE	TRISINK	TRIPLE BASIN SINK
1 1/2" LV	1 1/2" LOOP VENT	BAR	BAR SINK
2" LV	2" LOOP VENT	DWASH.	DISHWASHER
2" VTR	2" VENT THRU ROOF	2" F.D.	2" FLOOR DRAIN
3" VTR	3" VENT THRU ROOF	3" F.D.	3" FLOOR DRAIN
C.O.T.G.	CLEAN-OUT TO GRADE	3" F.S.	3" FLOOR SINK
C.O.	CLEAN-OUT	EWC	ELECTRIC WATER COOLER
W.C.O.	WALL CLEAN-OUT	EWI	ELECTRIC WATER HEATER
F.C.O.	FLOOR CLEAN-OUT	GW	GAS WATER HEATER
LAV.	LAVATORY	TRAY	LAUNDRY TRAY (SINK)
W.C.	WATER CLOSET (TOILET)	WASH.	WASHING MACHINE
BID.	BIDET	H.B.	HOSE BIBB
URNL	URINAL	TO SAN. DISP.	TO SANITARY DISPOSAL

NOTE:
PLUMBING CONTRACTOR SHALL PREPARE "AS-BUILT" SHOP DRAWINGS INDICATING ALL PLUMBING WORK INCLUDING ALL PLUMBING LINE LOCATIONS AND RISER DIAGRAM - CONTR SHALL PROVIDE 1 COPY OF AS-BUILT DUGS TO OWNER AND 1 COPY TO THE PERMIT ISSUING AUTHORITY.

NOTE:
PROVIDE PLUMBING CLEAN-OUTS AT THE BASE OF ALL STACKS, A MAXIMUM OF 18" O.C. ALONG ALL MAIN DRAIN RUNS AND THE UP-STREAM ENDS OF MAIN DRAIN RUNS, WHERE THE MAIN BUILDING DRAIN EXITS THE BUILDING AND AT 15' INTERVALS TO THE DISPOSAL SITE.

NOTE:
PROVIDE TRAP PRIMERS FOR ALL FLOOR DRAINS - PRIME EACH F.D. INDIVIDUALLY, DO NOT MANFOLD

NOTE:
WHERE PRACTICAL, & CODE ALLOWABLE, PLUMBING CONTRACTOR SHALL LOOP VENTS TO REDUCE ROOF PENETRATIONS

REVISION:
02 SEP 2020

Copyright, 2020
N.P. Gesler, Architect

DRAWN:
npg

ASSISTED LIVING FACILITY for
SMITH - SORENSEN
LAKE CITY, COLUMBIA COUNTY, FLORIDA
PROPOSED FLOOR PLAN

Collaborating
48 Years of Service
1972-2020
N.P. Gesler, Architect
AR0007005


NG
NICHOLAS
GESLER
ARCHITECT
N.C.A.R.B. Certified
1758 NW Bwn. Rd.
386-3251-425

DATE:
18 AUG 2020
CONTRACT:
2K2040

SHEET:
PME.1
1 OF 7


AR0007005

Digitally signed by N.P. GESLER
DN: cn = N.P. GESLER, c = US
Date: 2020.08.18 09:06:05 -0500

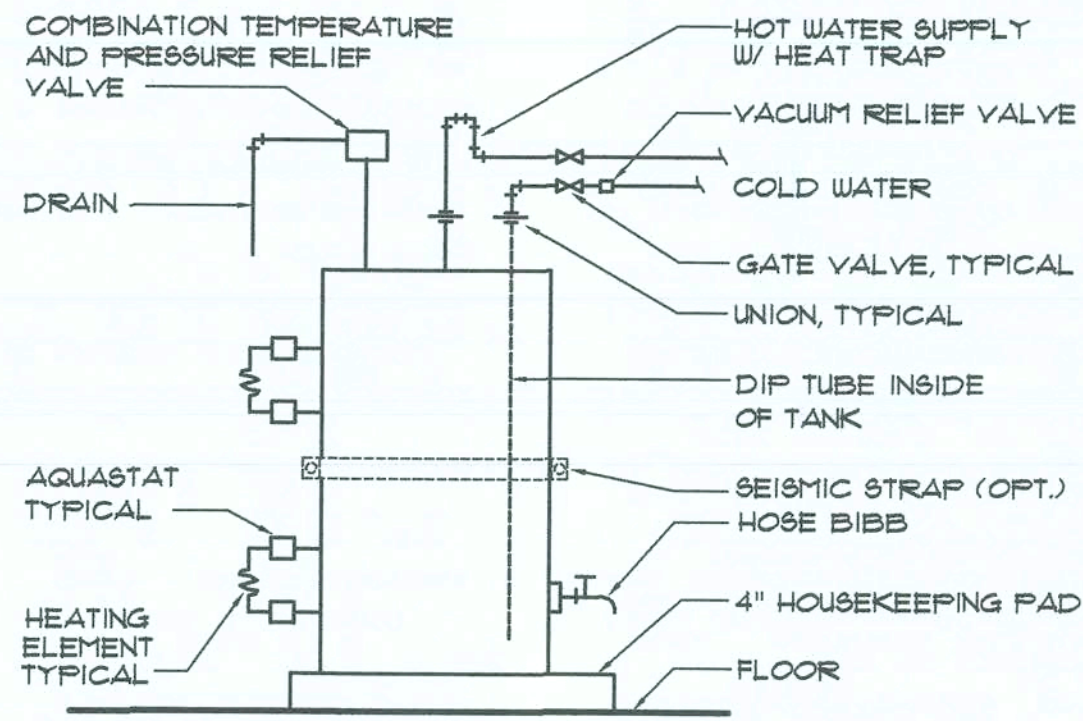


E.W.H. DETAIL
SCALE: NONE

A

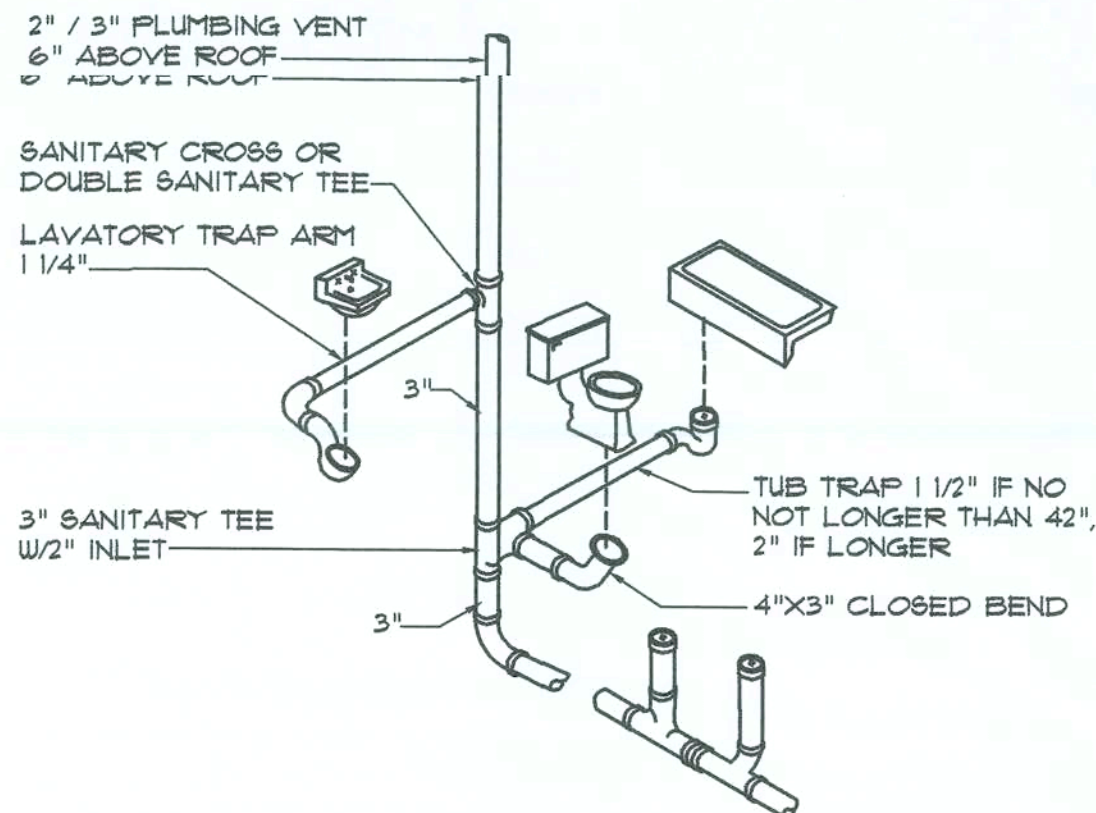


Typ. Bath Plumbing DET.
N.T.S.
N.T.S. - THIS PLUMBING DIAGRAM IS GENERAL IN NATURE, REFER TO THE 'PLUMBING RISER DIAGRAM' FOR INFORMATION.

B

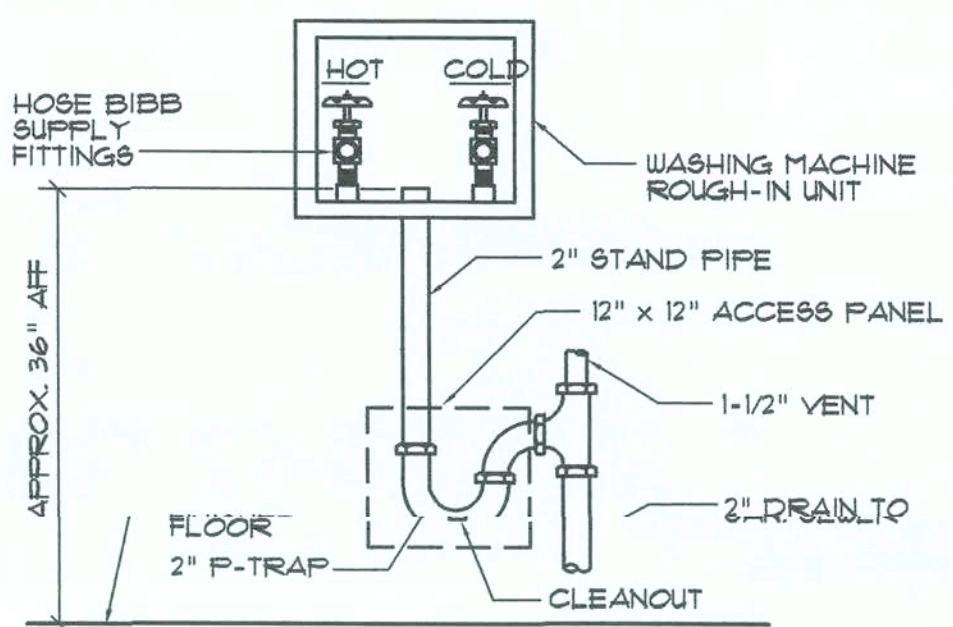

Wash. Mach. Hook-up DET.
N.T.S.

C

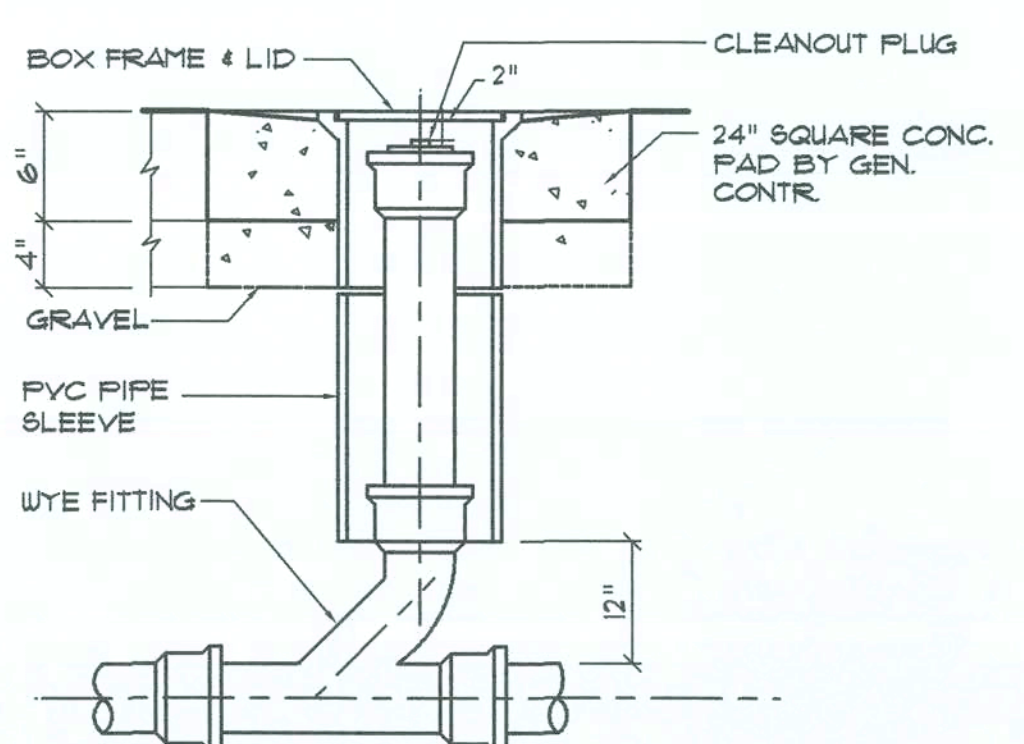

Outdoor Cleanout DETAIL
N.T.S.

D

GENERAL PLUMBING NOTES:

1. SUB-CONTRACTORS PROVIDING PLUMBING MATERIALS AND INSTALLATION SHALL BE SUBJECT TO THE PROVISIONS OF NOTES 1 THRU 6.
2. ALL WORKMANSHIP AND MATERIALS SHALL BE IN STRICT ACCORDANCE WITH APPLICABLE LOCAL CODES, RULES AND ORDINANCES.
3. ALL MATERIALS SHALL BE NEW.
4. ALL WORK SHALL BE PERFORMED BY A LICENSED PLUMBING CONTRACTOR IN A FIRST CLASS WORKMANLIKE MANNER. THE COMPLETED SYSTEM SHALL BE FULLY OPERATIONAL.
5. ALL EXCAVATION & BACKFILL AS REQUIRED FOR THIS PHASE OF THE CONSTRUCTION SHALL BE PART OF THE PLUMBING SUB-CONTRACTOR'S RESPONSIBILITIES.
6. PLUMBING FLAT PLANS AND RISER DIAGRAMS (IF INCLUDED) ARE DIAGRAMATIC, DO NOT SCALE THE DRAWINGS FOR EXACT LOCATIONS OF THE PLUMBING FIXTURES.
7. ALL WORK SHALL BE COORDINATED WITH OTHER TRADES TO AVOID INTERFERENCE WITH THE PROGRESS OF THE CONSTRUCTION.
8. WATER PIPING SHALL BE TYPE L COPPER UP TO 1", & TYPE K FOR ALL LARGER SIZES. ALL UNDERGROUND PIPING SHALL BE TYPE K COPPER. AT THE OWNER'S OPTION SUPPLY PIPING MAY BE C.P.V.C. SCHEDULE 40 OR SCHEDULE 80.
9. DO NOT USE LEAD BASED SOLDER FOR JOINING SUPPLY PIPING.
10. SOIL, WASTE, VENT & RAINWATER PIPING SHALL BE CAST IRON NO-HUB 301-12 ABOVE GRADE WITH NEOPRENE GASKETS AND STAINLESS STEEL BANDS & BELL & SPIGOT CAST IRON BELOW GRADE W/ LEAD & OAKUM JOINTS OR AT THE OWNER'S OPTION, P.V.C. SCHEDULE 40, SEE NOTE 12.
11. AIR CONDITIONING CONDENSATE DRAIN PIPING SHALL BE THREADED STEEL PIPE, COPPER DRAIN, WASTE OR VENT PIPE AND FITTINGS, OR P.V.C. SEE NOTE 12 BELOW INSULATE ALL CONDENSATE PIPING EXCEPT P.V.C. SEE NOTE 12 BELOW INSULATE ALL CONDENSATE PIPING EXCEPT WHERE UNDERGROUND, AND ELECTRIC HEAT WRAP WHERE EXPOSED TO FREEZING CONDITIONS.
12. P.V.C. SCHEDULE 40 PIPE AND FITTINGS MAY BE USED FOR SOIL, WASTE, VENT, RAINWATER OR CONDENSATE PIPING AS APPROPRIATE, WHERE APPROVED BY LOCAL BUILDING CODES & OFFICIALS. P.V.C. MAY NOT BE USED TO PENETRATE CHASES OR FIRE RATED WALLS / CEILING.
13. ALL FIXTURES MUST BE PROVIDED WITH READILY ACCESSIBLE STOPS AND WHERE PROVIDED, MARKED ACCESS PANELS.
14. FURNISH AND INSTALL APPROVED AIR CHAMBERS AT EACH PLUMBING FIXTURE AND APPROVED SHOCK ARRESTERS ON MAIN LINE OR RISERS.
15. DIELECTRIC COUPLINGS ARE REQUIRED BETWEEN ALL DISSIMILAR METALS IN PIPING AND EQUIPMENT CONNECTIONS.
16. ISOLATE COPPER PIPING FROM HANGERS OR SUPPORTS W/ HAIR FELT INSULATOR PADS.
17. PROVIDE 1/2" TRAP PRIMER LINE FOR ALL FLOOR DRAINS FROM NEAREST PLUMBING FIXTURE, DO NOT MANIFOLD.
18. PROVIDE ACCESS PANELS FOR ALL CONCEALED VALVES.
19. PROVIDE COMBINATION COVERPLATE / CLEANOUT PLUG FOR ALL WALL CLEANOUTS, FINISH AS DIRECTED BY THE OWNER.
20. FIXTURES, HARDWARE, EQUIPMENT, COLORS AND FINISHES SHALL BE AS SELECTED BY THE OWNER.

GENERAL WELL & SEPTIC NOTES:

1. SUB-CONTRACTORS PROVIDING WATER WELLS AND/OR SEPTIC TANKS AND DRAINFIELDS SHALL BE SUBJECT TO THE PROVISIONS OF NOTES 1 THRU 6, THIS SHEET.
2. LOCATION OF POTABLE WATER WELLS SHALL BE DETERMINED BY THE OWNER IN CONSULTATION WITH THE WELL DRILLING CONTRACTOR. WELLS SHALL NOT BE LOCATED CLOSER THAN 15'-0" TO ANY PROPOSED OR EXISTING SEPTIC TANK OR DRAINFIELD, EITHER ON SUBJECT PROPERTY OR ADJACENT/ADJOINING PROPERTY.
3. POTABLE WATER WELLS SHALL BE A MINIMUM 4" WITH BLACK IRON CASING TO A DEPTH OF 80'-0". PUMPS SHALL BE OF THE SUBMERSIBLE TYPE, THREE WIRE SYSTEM, MINIMUM HORSEPOWER SHALL BE 1/2 H/P OR AS DIRECTED BY THE OWNER. MOTOR STARTER SHALL BE ENCLOSED IN A WEATHERPROOF HOUSING, MOUNTED ON A P/T 4X4 POST AT THE WELL HEAD.
4. WELL HEAD SHALL PROJECT 12" ABOVE GRADE.
5. ALL REQUIRED COMPONENTS FOR A COMPLETE OPERATING SYSTEM SHALL BE PROVIDED, INCLUDING ANTI-FREEZE BLEEDER FITTING, CHECKVALVE, AIR BLEEDERS, SHUTOFF VALVE, HOSE BIBB, PRESSURE REGULATOR/CONTROLLER, UNIONS AND PRESSURE GAUGE.
6. PRESSURE TANK SHALL BE GALVANIZED 82 GALLON CAPACITY, UNLESS DIRECTED OTHERWISE BY THE OWNER.
7. SEPTIC TANK LOCATION & DRAINFIELD INVERT SHALL BE DETERMINED BY THE LOCAL HEALTH DEPARTMENT, IN CONSULTATION W/ THE OWNER.
8. SEPTIC TANKS SHALL BE OF A SIZE & CONSTRUCTION AS DETERMINED BY THE LOCAL HEALTH DEPARTMENT. TANK MAT'L SHALL BE POURED CONCRETE OR FIBERGLASS AS ALLOWED BY THE SEPTIC TANK PERMIT.
9. SEPTIC DRAINFIELDS SHALL BE CONSTRUCTED TO THE STANDARDS OF THE LOCAL HEALTH DEPARTMENT. DRAINFIELD PIPING SHALL BE CLAY TILE OR P.V.C. OR POLY AS ALLOWED BY THE SEPTIC TANK PERMIT. DRAINFIELD BEDS SHALL BE 3/4" WASHED ROCK, INSTALLED THICKNESS SHALL BE AS PER SEPTIC TANK PERMIT.
10. SAND FILTER BEADS, MOUND SYSTEMS, DOSING TANKS, GREASE TRAPS, DISTRIBUTION BOXES, GRINDER PUMPS, SHUP PUMPS AND OTHER SUCH RELATED ITEMS (IF REQUIRED OR REQUESTED) SHALL BE AS PER THE DESIGN STANDARDS OF THE LOCAL HEALTH DEPARTMENT.

FIELD "AS-BUILT" NOTES:

Field "As-Built" Notes section with multiple horizontal lines for handwritten notes.

REVISION:

Copyright 2020
N.P. Geisler, Architect

DRAWN:
198

ASSISTED LIVING FACILITY for
GRANDE CYPRESS
LAKE CITY, COLUMBIA COUNTY, FLORIDA
PLUMBING DETAILS / AS-BUILT NOTES

Calculated by:
48 Years of Service

1972 - 2020
N.P. Geisler, Architect
Architect

NICHOLAS
PAUL
GEISLER
ARCHITECT
N.C.A.R.B. Certified

1755 NW 82nd Ave.
Lake City, FL 32055
386-363-4455

DATE:
18 AUG 2020


CONTRACT:
2K2040

SHEET:
PME.2
2 of 7

AR0007005

Digitally signed by: N.P. GEISLER
DN: cn=N.P. GEISLER, c=US
Date: 2020.08.18 09:41:15-07'

These drawings, as instruments of service, are the sole property of the architect, and may not be used, copied or reproduced in whole or in part for use on or incorporated within any other job without specific and individual authorization by the architect.

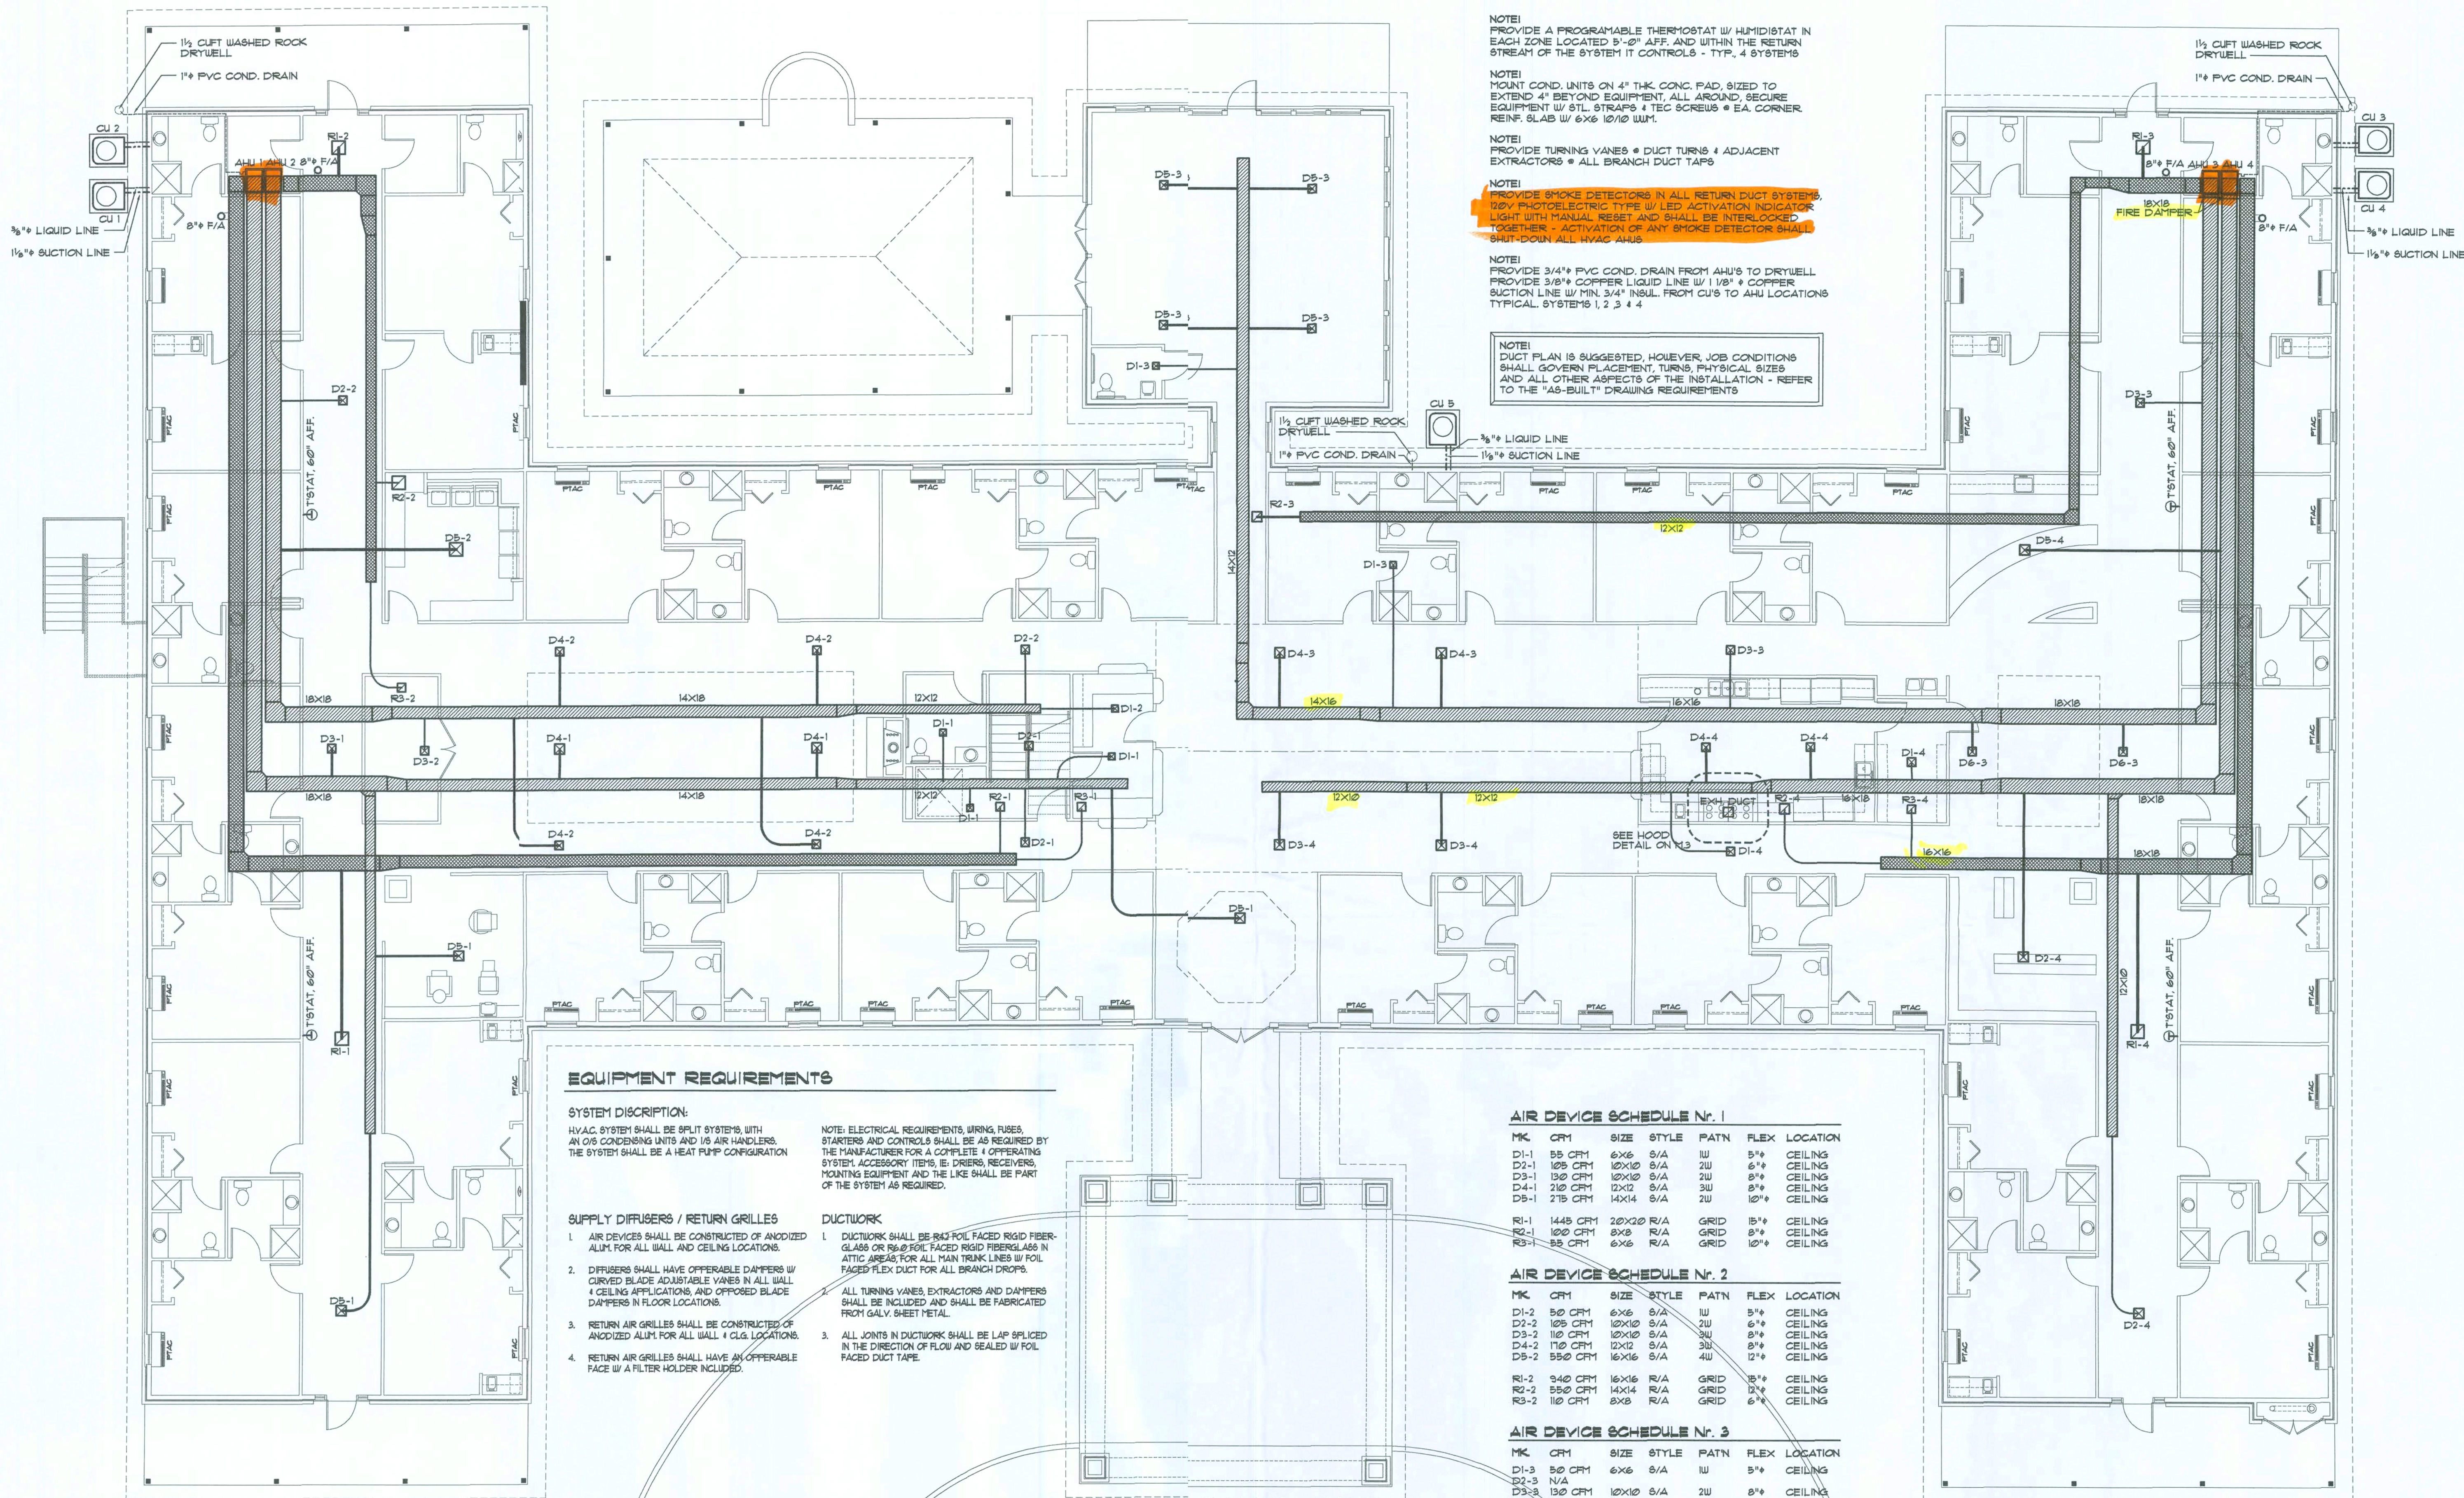

EQUIPMENT REQUIREMENTS

SYSTEM DESCRIPTION:
HVAC SYSTEM SHALL BE SPLIT SYSTEMS WITH AN O/S CONDENSING UNITS AND IS AIR HANDLERS. THE SYSTEM SHALL BE A HEAT PUMP CONFIGURATION.

NOTE: ELECTRICAL REQUIREMENTS, WIRING, FUSES, STARTERS AND CONTROLS SHALL BE AS REQUIRED BY THE MANUFACTURER FOR A COMPLETE OPERATING SYSTEM. ACCESSORY ITEMS, IE: DRIERS, RECEIVERS, MOUNTING EQUIPMENT AND THE LIKE SHALL BE PART OF THE SYSTEM AS REQUIRED.

SUPPLY DIFFUSERS / RETURN GRILLES

- AIR DEVICES SHALL BE CONSTRUCTED OF ANODIZED ALUM. FOR ALL WALL AND CEILING LOCATIONS.
- DIFFUSERS SHALL HAVE OFFERABLE DAMPERS W/ CURVED BLADE ADJUSTABLE VANES IN ALL WALL & CEILING APPLICATIONS AND OFFERED BLADE DAMPERS IN FLOOR LOCATIONS.
- RETURN AIR GRILLES SHALL BE CONSTRUCTED OF ANODIZED ALUM. FOR ALL WALL & CLG LOCATIONS.
- RETURN AIR GRILLES SHALL HAVE AN OFFERABLE FACE W/ A FILTER HOLDER INCLUDED.

DUCTWORK

- DUCTWORK SHALL BE 8-1/2" RIGID FIBERGLASS OR 8-1/2" RIGID FIBERGLASS IN ATTIC AREAS, FOR ALL MAIN TRUNK LINES W/ FOL FACED FLEX DUCT FOR ALL BRANCH DROPS.
- ALL TURNING VANES, EXTRACTORS AND DAMPERS SHALL BE INCLUDED AND SHALL BE FABRICATED FROM GALV. SHEET METAL.
- ALL JOINTS IN DUCTWORK SHALL BE LAP SPICED IN THE DIRECTION OF FLOW AND SEALED W/ FOL FACED DUCT TAPE.

NOTE:
PROVIDE A PROGRAMMABLE THERMOSTAT W/ HUMIDISTAT IN EACH ZONE LOCATED 5'-0" AFF. AND WITHIN THE RETURN STREAM OF THE SYSTEM IT CONTROLS - TYP. 4 SYSTEMS

NOTE:
MOUNT COND. UNITS ON 4" THK CONC. PAD, SIZED TO EXTEND 4" BEYOND EQUIPMENT, ALL AROUND, SECURE EQUIPMENT W/ STL STRAPS & TEC SCREWS @ EA. CORNER. REINF. SLAB W/ 6X6 10/10 WWT.

NOTE:
PROVIDE TURNING VANES @ DUCT TURNS & ADJACENT EXTRACTORS @ ALL BRANCH DUCT TAPS

NOTE:
PROVIDE SMOKE DETECTORS IN ALL RETURN DUCT SYSTEMS, 120V PHOTOELECTRIC TYPE W/ LED ACTIVATION INDICATOR LIGHT WITH MANUAL RESET AND SHALL BE INTERLOCKED TOGETHER - ACTIVATION OF ANY SMOKE DETECTOR SHALL SHUT-DOWN ALL HVAC AHUS

NOTE:
PROVIDE 3/4" PVC COND. DRAIN FROM AHU'S TO DRYWELL. PROVIDE 3/8" COPPER LIQUID LINE W/ 1/8" COPPER SUCTION LINE W/ MIN. 3/4" INSUL. FROM CU'S TO AHU LOCATIONS TYPICAL SYSTEMS 1, 2, 3 & 4

NOTE:
DUCT PLAN IS SUGGESTED, HOWEVER, JOB CONDITIONS SHALL GOVERN PLACEMENT, TURNS, PHYSICAL SIZES AND ALL OTHER ASPECTS OF THE INSTALLATION - REFER TO THE "AS-BUILT" DRAWING REQUIREMENTS

AIR DEVICE SCHEDULE No. 1						
NO.	CFM	SIZE	STYLE	PATN	FLEX	LOCATION
D1-1	55 CFM	6"x6"	S/A	1W	5"	CEILING
D2-1	105 CFM	10"x10"	S/A	2W	6"	CEILING
D3-1	130 CFM	10"x10"	S/A	2W	8"	CEILING
D4-1	210 CFM	12"x12"	S/A	3W	8"	CEILING
D5-1	215 CFM	14"x14"	S/A	2W	10"	CEILING

AIR DEVICE SCHEDULE No. 2						
NO.	CFM	SIZE	STYLE	PATN	FLEX	LOCATION
D1-2	50 CFM	6"x6"	S/A	1W	5"	CEILING
D2-2	105 CFM	10"x10"	S/A	2W	6"	CEILING
D3-2	110 CFM	10"x10"	S/A	3W	8"	CEILING
D4-2	110 CFM	12"x12"	S/A	3W	8"	CEILING
D5-2	550 CFM	16"x16"	S/A	4W	12"	CEILING

AIR DEVICE SCHEDULE No. 3						
NO.	CFM	SIZE	STYLE	PATN	FLEX	LOCATION
D1-3	50 CFM	6"x6"	S/A	1W	5"	CEILING
D2-3	N/A					
D3-3	130 CFM	10"x10"	S/A	2W	8"	CEILING
D4-3	225 CFM	12"x12"	S/A	3W	10"	CEILING
D5-3	180 CFM	14"x14"	S/A	4W	12"	CEILING
D6-3	215 CFM	14"x14"	S/A	2W	12"	CEILING

AIR DEVICE SCHEDULE No. 4						
NO.	CFM	SIZE	STYLE	PATN	FLEX	LOCATION
D1-4	100 CFM	8"x8"	S/A	2W	6"	CEILING
D2-4	210 CFM	12"x12"	S/A	4W	10"	CEILING
D3-4	225 CFM	12"x12"	S/A	3W	10"	CEILING
D4-4	240 CFM	14"x14"	S/A	4W	12"	CEILING
D5-4	250 CFM	14"x14"	S/A	4W	12"	CEILING

H. V. A. C. PLAN

SCALE: 1/8" = 1'-0"

NOTE:
HVAC CONTRACTOR SHALL PREPARE "AS-BUILT" SHOP DRAWINGS INDICATING ALL HVAC WORK INCLUDING ALL DUCTWORK LOC. SIZES, LINES, EQUIPMENT SCH. & BALANCING REPORT - CONTR SHALL PROVIDE 1 COPY OF AS-BUILT DUGS TO OWNER & 1 COPY TO THE PERMIT ISSUING AUTHORITY.

EQUIPMENT SPECIFICATION:									
SYST.	TOTAL COOL	SENSIBLE	HEATING	SEER	HSPF	EF	KW	CFM	VOLTAGE
1, 2, 4	48000 BTU	36000 BTU	41°F DB + 40000 BTU 11°F DB + 31200 BTU	14.50	8.00	31	3.65	16000	240V - 1P
3, 5	60000 BTU	46200 BTU	41°F DB + 60000 BTU 11°F DB + 39600 BTU	14.50	8.00	31	4.65	20000	240V - 1P
PTAC	12000 BTU	9000 BTU	41°F DB + 12000 BTU 11°F DB + 6900 BTU	14.50	8.00	-	1.8	800	240V - 1P

EQUIPMENT BY LISTED MFG'S MEETING OR EXCEEDING THESE PERFORMANCE RATINGS ARE APPROVED, AS EQUAL

A. RHEEM / RUUD	D. YORK
B. CARRIER	E. LENNOX
C. TRANE	F. BRYANT

REVISION:
01 SEP 2020

Copyright 2020
N.J. Gesler, Architect

DRAWN:
npg

ASSISTED LIVING FACILITY for
SMITH - SORENSEN
LAKE CITY, COLUMBIA COUNTY, FLORIDA
HVAC PLAN

48 Years of Service
1972-2020
N.J. Gesler, Architect
AR0007005

**NICHOLAS
GESLER
ARCHITECT**
N.C.A.R.B. Certified
1755 NW Brown Rd.
388-365-4355

DATE:
10 AUG 2020

CONR:
2K2040


SHEET:

PME.3

3 OF 7

AR0007005

These drawings, as instruments of service, are the sole property of the architect, and may not be used, copied or reproduced in whole or in part for use on or incorporated within any other job without specific and individual authorization by the architect.

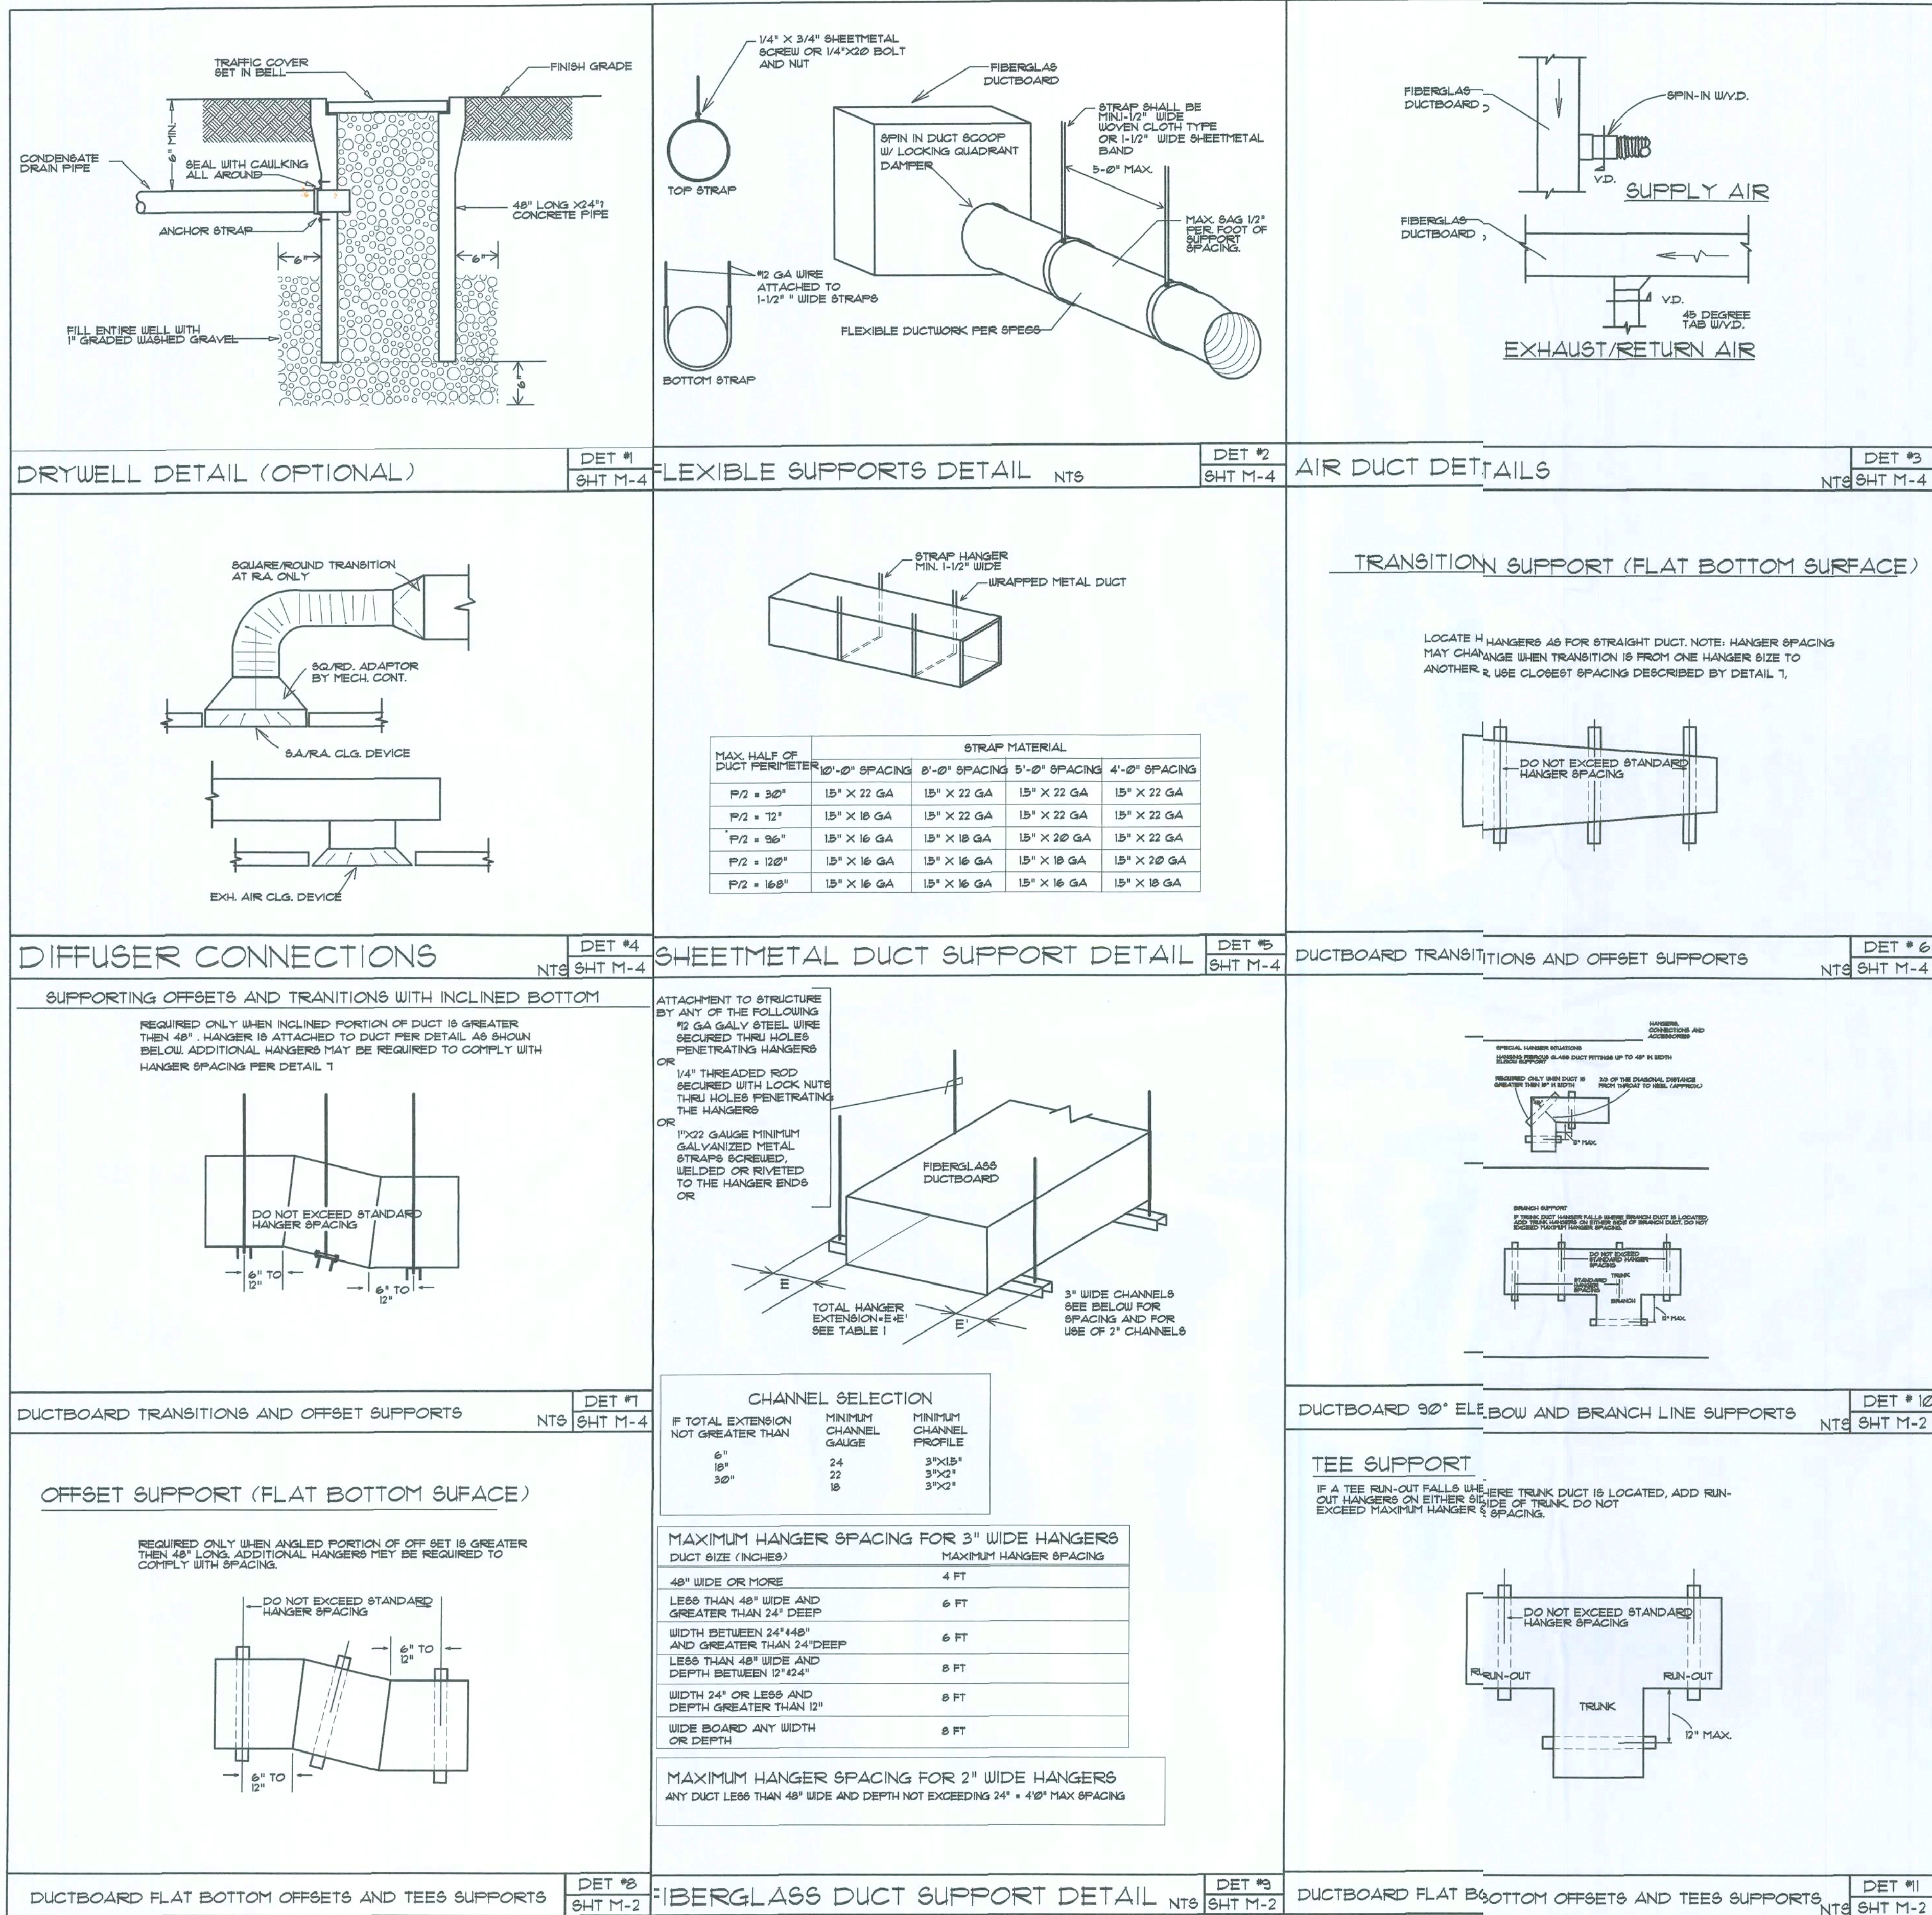

GENERAL H.V.A.C. NOTES:

- SUB-CONTRACTORS PROVIDING HVAC INSTALLATION SHALL BE SUBJECT TO THE PROVISIONS OF NOTES 1 THRU 6, GENERAL NOTES/D.I.s.
- HVAC SUB-CONTRACTOR SHALL PROVIDE ALL LABOR, MATERIALS, TOOLS AND EQUIPMENT TO INSTALL A COMPLETE & OPERATING HVAC SYSTEM.
- HVAC SYSTEM SHALL BE AS DETAILED IN THE PLANS (IF INCLUDED), OR SHALL BE AS DIRECTED BY THE OWNER IN CONSULTATION WITH THE HVAC SUB-CONTRACTOR.
- HVAC SUB-CONTRACTOR SHALL FURNISH SHOP DRAWINGS FOR DUCTWORK, CONDENSING UNIT & AIR HANDLER, EXHAUST FANS AND AIR DEVICES.
- IT IS THE HVAC SUB-CONTRACTOR'S RESPONSIBILITY TO COMPLY WITH NFPA-90A AND ALL APPLICABLE CODES.
- FLEXIBLE DUCT SHALL BE FULLY ANNEALED, CORRUGATED ALUMINUM W/ 1 3/4 LB. DENSITY FIBERGLASS INSULATION AND SHALL BE UL LISTED. SHEET METAL DUCT SHALL BE LINED W/ 1" MATFACED DUCT LINER & WRAPPED W/ 1 3/4 LB. FOILFACED FIBERGLASS INSULATION. ALL FIBERGLASS DUCT SHALL BE FOILFACED, R42/R6 0 DUCTBOARD.
- ALL EXHAUST AND OUTSIDE AIR DUCT SHALL BE GALVANIZED SHEET METAL CONSTRUCTED AND INSTALLED IN ACCORDANCE WITH ASHREA AND SMACNA STANDARDS.
- ALL AIR DEVICES SHALL BE OF ALUMINUM CONSTRUCTION FOR WALL AND CEILING APPLICATIONS AND STEEL CONSTRUCTION IN FLOOR APPLICATIONS. ACCEPTABLE MANUFACTURERS SHALL BE TITUS, METALAIR, NAILORHART, HART & COOLIE OR AS DIRECTED BY THE OWNER.
- IF REQUIRED BY THE OWNER, THE HVAC SUB-CONTRACTOR SHALL SUPPLY A TEST AND BALANCE REPORT IN ACCORDANCE WITH AIR BALANCE COUNCIL STANDARDS, SIGN AND SEALED BY A REGISTERED ENGINEER.
- HVAC SUB-CONTRACTOR SHALL SUPPLY ALL CONTRACTORS, RELAYS, AND THERMOSTATS. THE ELECTRICAL SUB-CONTRACTOR SHALL PROVIDE ALL SWITCHES, DISCONNECTS & CONTROL WIRING. THERMOSTATS SHALL BE APPROVED BY THE EQUIPMENT MFG'R.
- ALL DUCT SIZES INDICATED IN THE PLANS (IF INCLUDED) ARE NET INSIDE DIMENSIONS.
- ALL EQUIPMENT SHALL BE FULLY WARRANTED FOR 1 YEAR AND THE COMPRESSOR(S) SHALL BE WARRANTED 5 YEARS FROM DATE OF FINAL ACCEPTANCE, BY THE OWNER.
- ALL WORK IN THIS TRADE SHALL BE COORDINATED WITH ALL OTHER TRADES SO AS TO AVOID CONFLICTS OR HINDERANCE TO COMPLETION OF THE JOB.
- CONDENSATE DRAIN PIPING SHALL BE INSULATED WITH 1/2" THICK ARMAFLEX INSULATION.
- FILTERS SHALL BE DISPOSABLE TYPE AND HAVE INITIAL SHARE WEIGHT ARRESTANCE OF 10% AND A CLEAN PRESSURE DROP OF 0.15. PROVIDE 2 SETS, ONE DURING CONSTRUCTION AND ONE FOR USE AT FINAL ACCEPTANCE.
- HVAC SUB-CONTRACTOR SHALL PROVIDE & INSTALL ALL NECESSARY OFFSETS, TRANSITIONS & BENDS REQUIRED TO PROVIDE A COMPLETE SYSTEM AT NO ADDITIONAL COST TO THE OWNER.
- IT IS THE RESPONSIBILITY OF THE HVAC SUB-CONTRACTOR TO COORDINATE LOCATION OF CEILING DIFFUSERS, GRILLES AND REGISTERS IN THE FIELD WITH THE ELECTRICIAN, LIGHTS AND ARCHITECTURAL ELEMENTS.
- COORDINATE W/ THE ELECTRICIAN, PARTICULARLY ELECTRICAL NOTE N-23, TO ASSURE SUITABLE SIZES OF BREAKERS, SWITCHES AND WIRING.

REVISION:

Copyright 2020
N.P. Geisler, Architect

DRAWN:
198

ASSISTED LIVING FACILITY FOR
GRANDE CYPRESS
LAKE CITY, COLUMBIA COUNTY, FLORIDA

HVAC DETAILS

Calculating
48 Years of Service

1972 - 2020
N.P. Geisler, Architect
LAKE CITY, FL 32055
386-568-4365

NICHOLAS
PAUL
GEISLER
ARCHITECT
N.C.A.R.B. Certified

DATE:
18 AUG 2020


CONTR:
2K2040

SHEET:
PME.4
4 OF 7

AR0017005

Digitally signed by: N. P. Geisler
O = AR0017005, OU = ARCHITECT
Date: 2020.08.06 10:59:45-07'


These drawings, as instruments of service, are the property of the architect, and may not be used, copied or reproduced in whole or in part for use on or incorporated within any other job without specific and individual authorization by the architect.

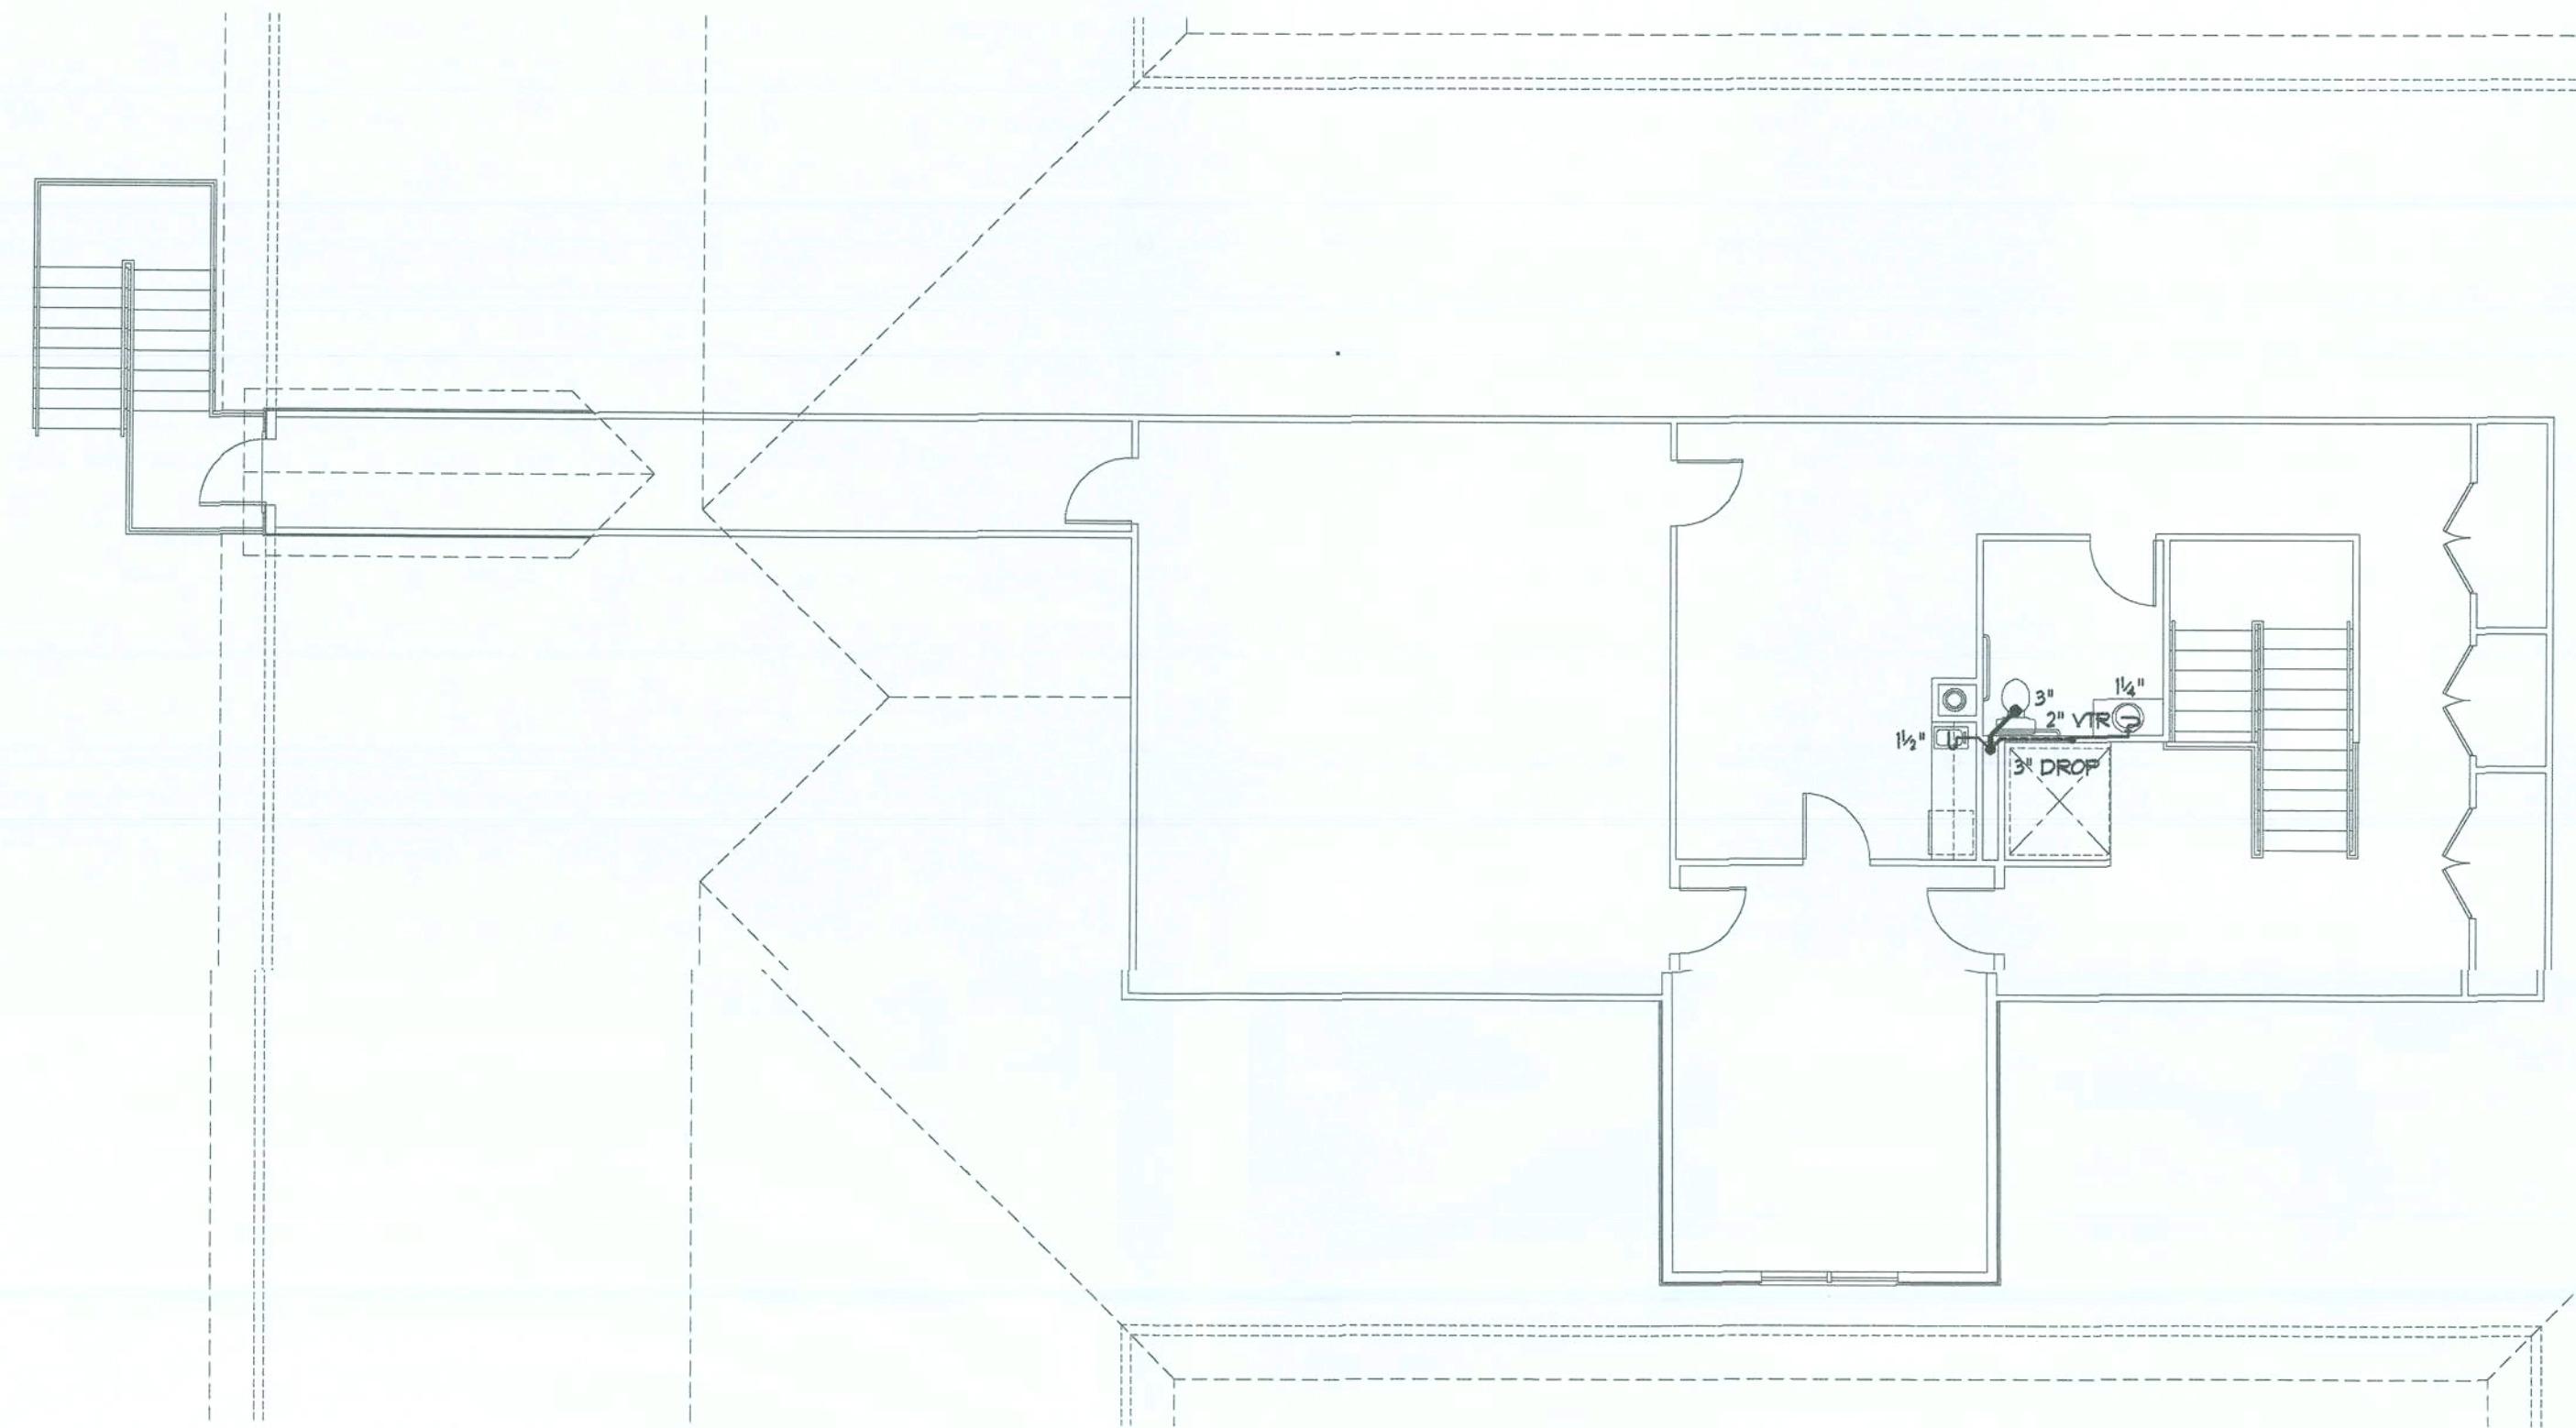

LOFT PLUMBING PLAN

SCALE: 1/8" = 1'-0"


NOTE!
REFER TO SHEETS PME.1 & PME.2 FOR
PLUMBING DATA AND DETAILS

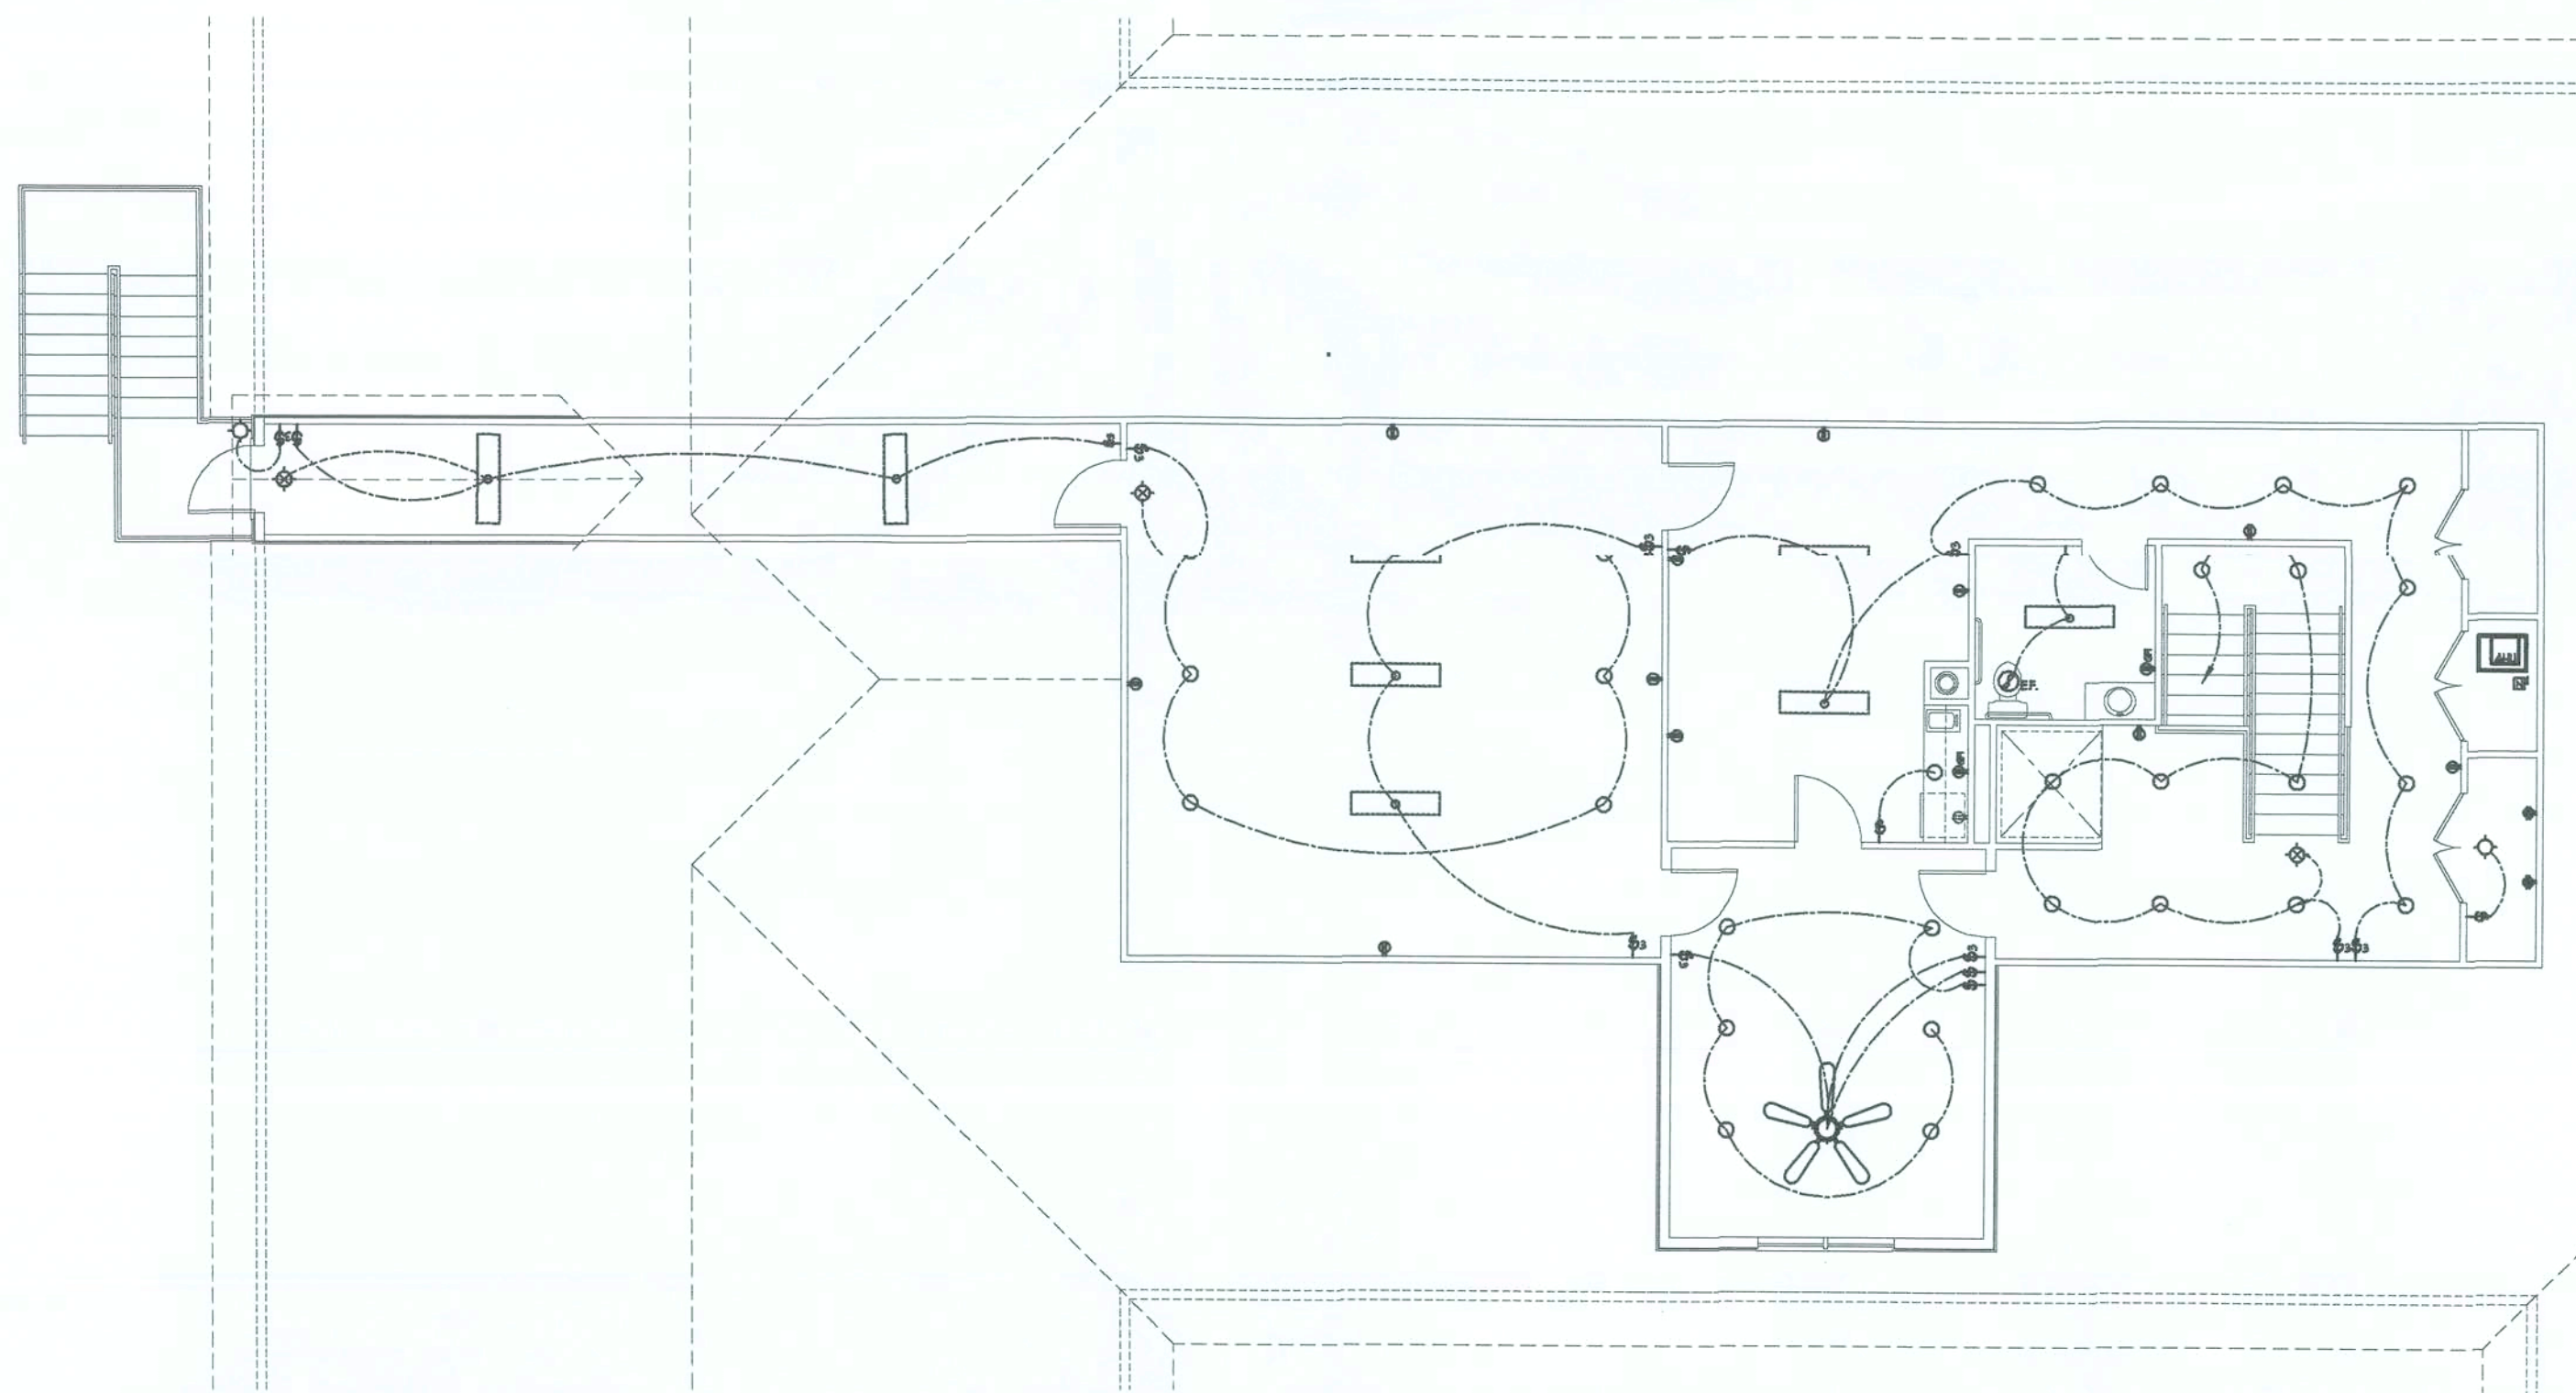

LOFT ELECTRICAL PLAN

SCALE: 1/8" = 1'-0"

NOTE!
REFER TO SHEETS PME.6 & PME.7 FOR
ELECTRICAL DATA AND DETAILS

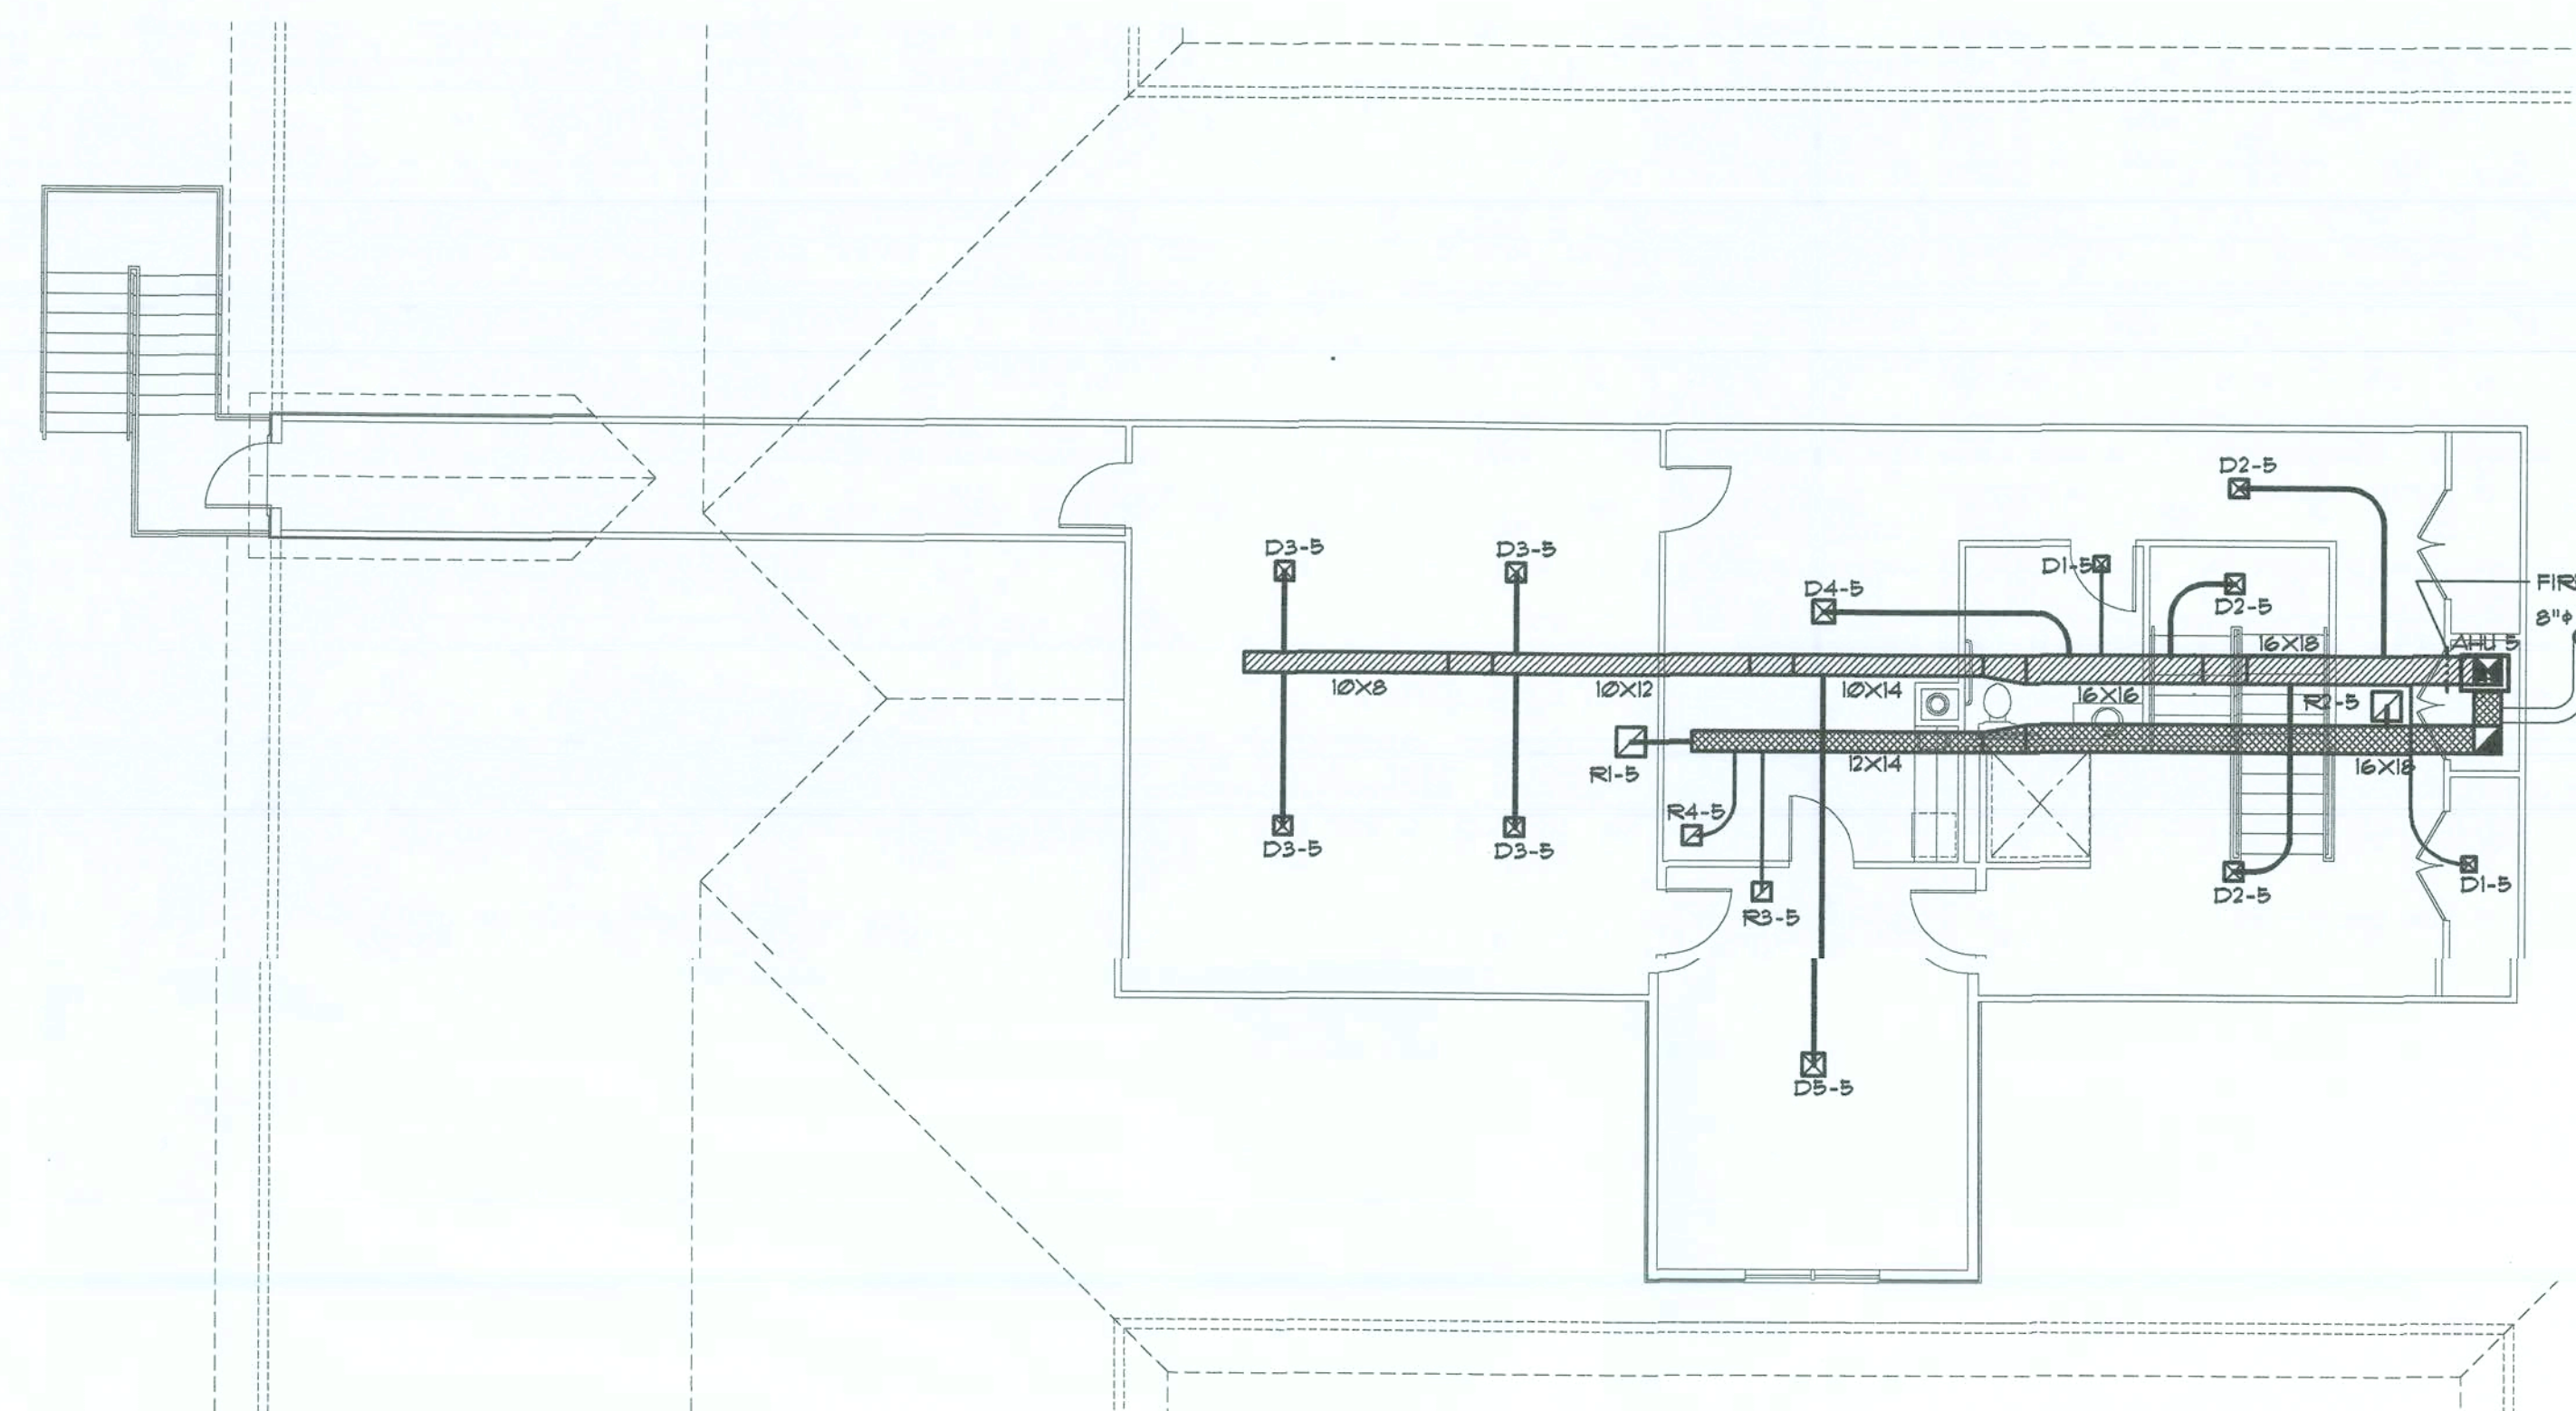

LOFT H. V. A. C. PLAN

SCALE: 1/8" = 1'-0"

NOTE!
REFER TO SHEETS PME.3 & PME.4 FOR
HVAC DATA AND DETAILS

AIR DEVICE SCHEDULE No. 5

NO.	CFM	SIZE	STYLE	PATN	FLEX	LOCATION
D1-5	45 CFM	6"X6"	S/A	1W	5"	CEILING
D2-5	115 CFM	10"X10"	S/A	2W	8"	CEILING
D3-5	190 CFM	12"X12"	S/A	4W	8"	CEILING
D4-5	305 CFM	14"X14"	S/A	4W	10"	CEILING
D5-5	320 CFM	14"X14"	S/A	4W	10"	CEILING
R1-5	160 CFM	16"X16"	R/A	GRID	12"	CEILING
R2-5	530 CFM	12"X12"	R/A	GRID	12"	CEILING
R3-5	330 CFM	10"X10"	R/A	GRID	10"	CEILING
R4-5	305 CFM	10"X10"	R/A	GRID	10"	CEILING

Electrical SYMBOLS

POWER

- ⊕ DUPLEX WALL RECEPTACLE
- ⊕ DUPLEX WALL RECEPT., BELOW COUNTER
- ⊕ 240V OUTLET
- ⊕ GND FAULT INTERRUPTER DUPLEX RECEPT.
- ⊕ WEATHER PROOF GFI DUPLEX RECEPT.
- ⊕ QUADRAPLEX WALL RECEPTACLE
- ⊕ JUNCTION BOX
- ⊕ MOTOR (SP - SUBMERSIBLE PUMP)
- ⊕ ELECTRICAL PANEL
- ⊕ ELECTRICAL PANEL
- ⊕ EXHAUST FAN
- ⊕ SMOKE DETECTOR, 120V
- ⊕ NON-FUSED DISC. SWITCH
- ⊕ CHIME
- ⊕ MOMENTARY PUSHBUTTON SWITCH, LIGHTED
- ⊕ HVAC THERMOSTAT, 60° AFF

LIGHTING

- ⊕ 8PST WALL SWITCH
- ⊕ DPDT WALL SWITCH (3-WAY)
- ⊕ L.E.D. CHANDELIER
- ⊕ CEILING FAN, W/ L.E.D. LIGHT FIXTURE
4 OR 5 BLADE, DECOR.
- ⊕ 2 STRIP L.E.D. PRISMATIC WRAP SURFACE FIXTURE
- ⊕ L.E.D. LIGHT FIXTURE
- ⊕ L.E.D. HIGH HAT DOWN LIGHT
- ⊕ VAPOR PROOF L.E.D. LIGHT FIXTURE
- ⊕ L.E.D. WALL BRACKET
- ⊕ INC. ROPE LIGHT W/ 5W LAMPS @ 4" O.C.
- ⊕ SWITCH/FIXTURE WIRING
- ⊕ CONTROL WIRE / LOW VOLTAGE
- ⊕ 36"1/20" 9 BLADE INDOOR/OUTDOOR
CEILING FAN PER "MODERN FORMS"
HYDRA 120" OR "BIG AIR" 36"

Digitally signed by: N. P. GESLER
O = NICHOLAS P. GESLER ARCHITECT
OU = AR0007005
CN = NICHOLAS P. GESLER ARCHITECT
Date: 2020.08.09 11:32:45-0700

REVISION:

Copyright, 2020
N.P. Gesler, Architect

DRAWN:

mpg

ASSISTED LIVING FACILITY for
SMITH - SORESEN
LAKE CITY, COLUMBIA COUNTY, FLORIDA
LOFT PME PLANS

Celebrating
48 Years of Service
1972-2020
N.P. Gesler, Architect
AR0007005


NICHOLAS P. GESLER
ARCHITECT
N.C.A.R.B. Certified
1758 NW Brown Rd.
Lake City, FL 33705
386-363-4365

DATE:
19 AUG 2020
COMM:
2K2040

SHEET:
PME.5
5 of 7

AR0007005

These drawings, as instruments of service, are the sole property of the architect, and may not be used, copied or reproduced in whole or in part for use on or incorporated within any other job without specific and individual authorization by the architect.

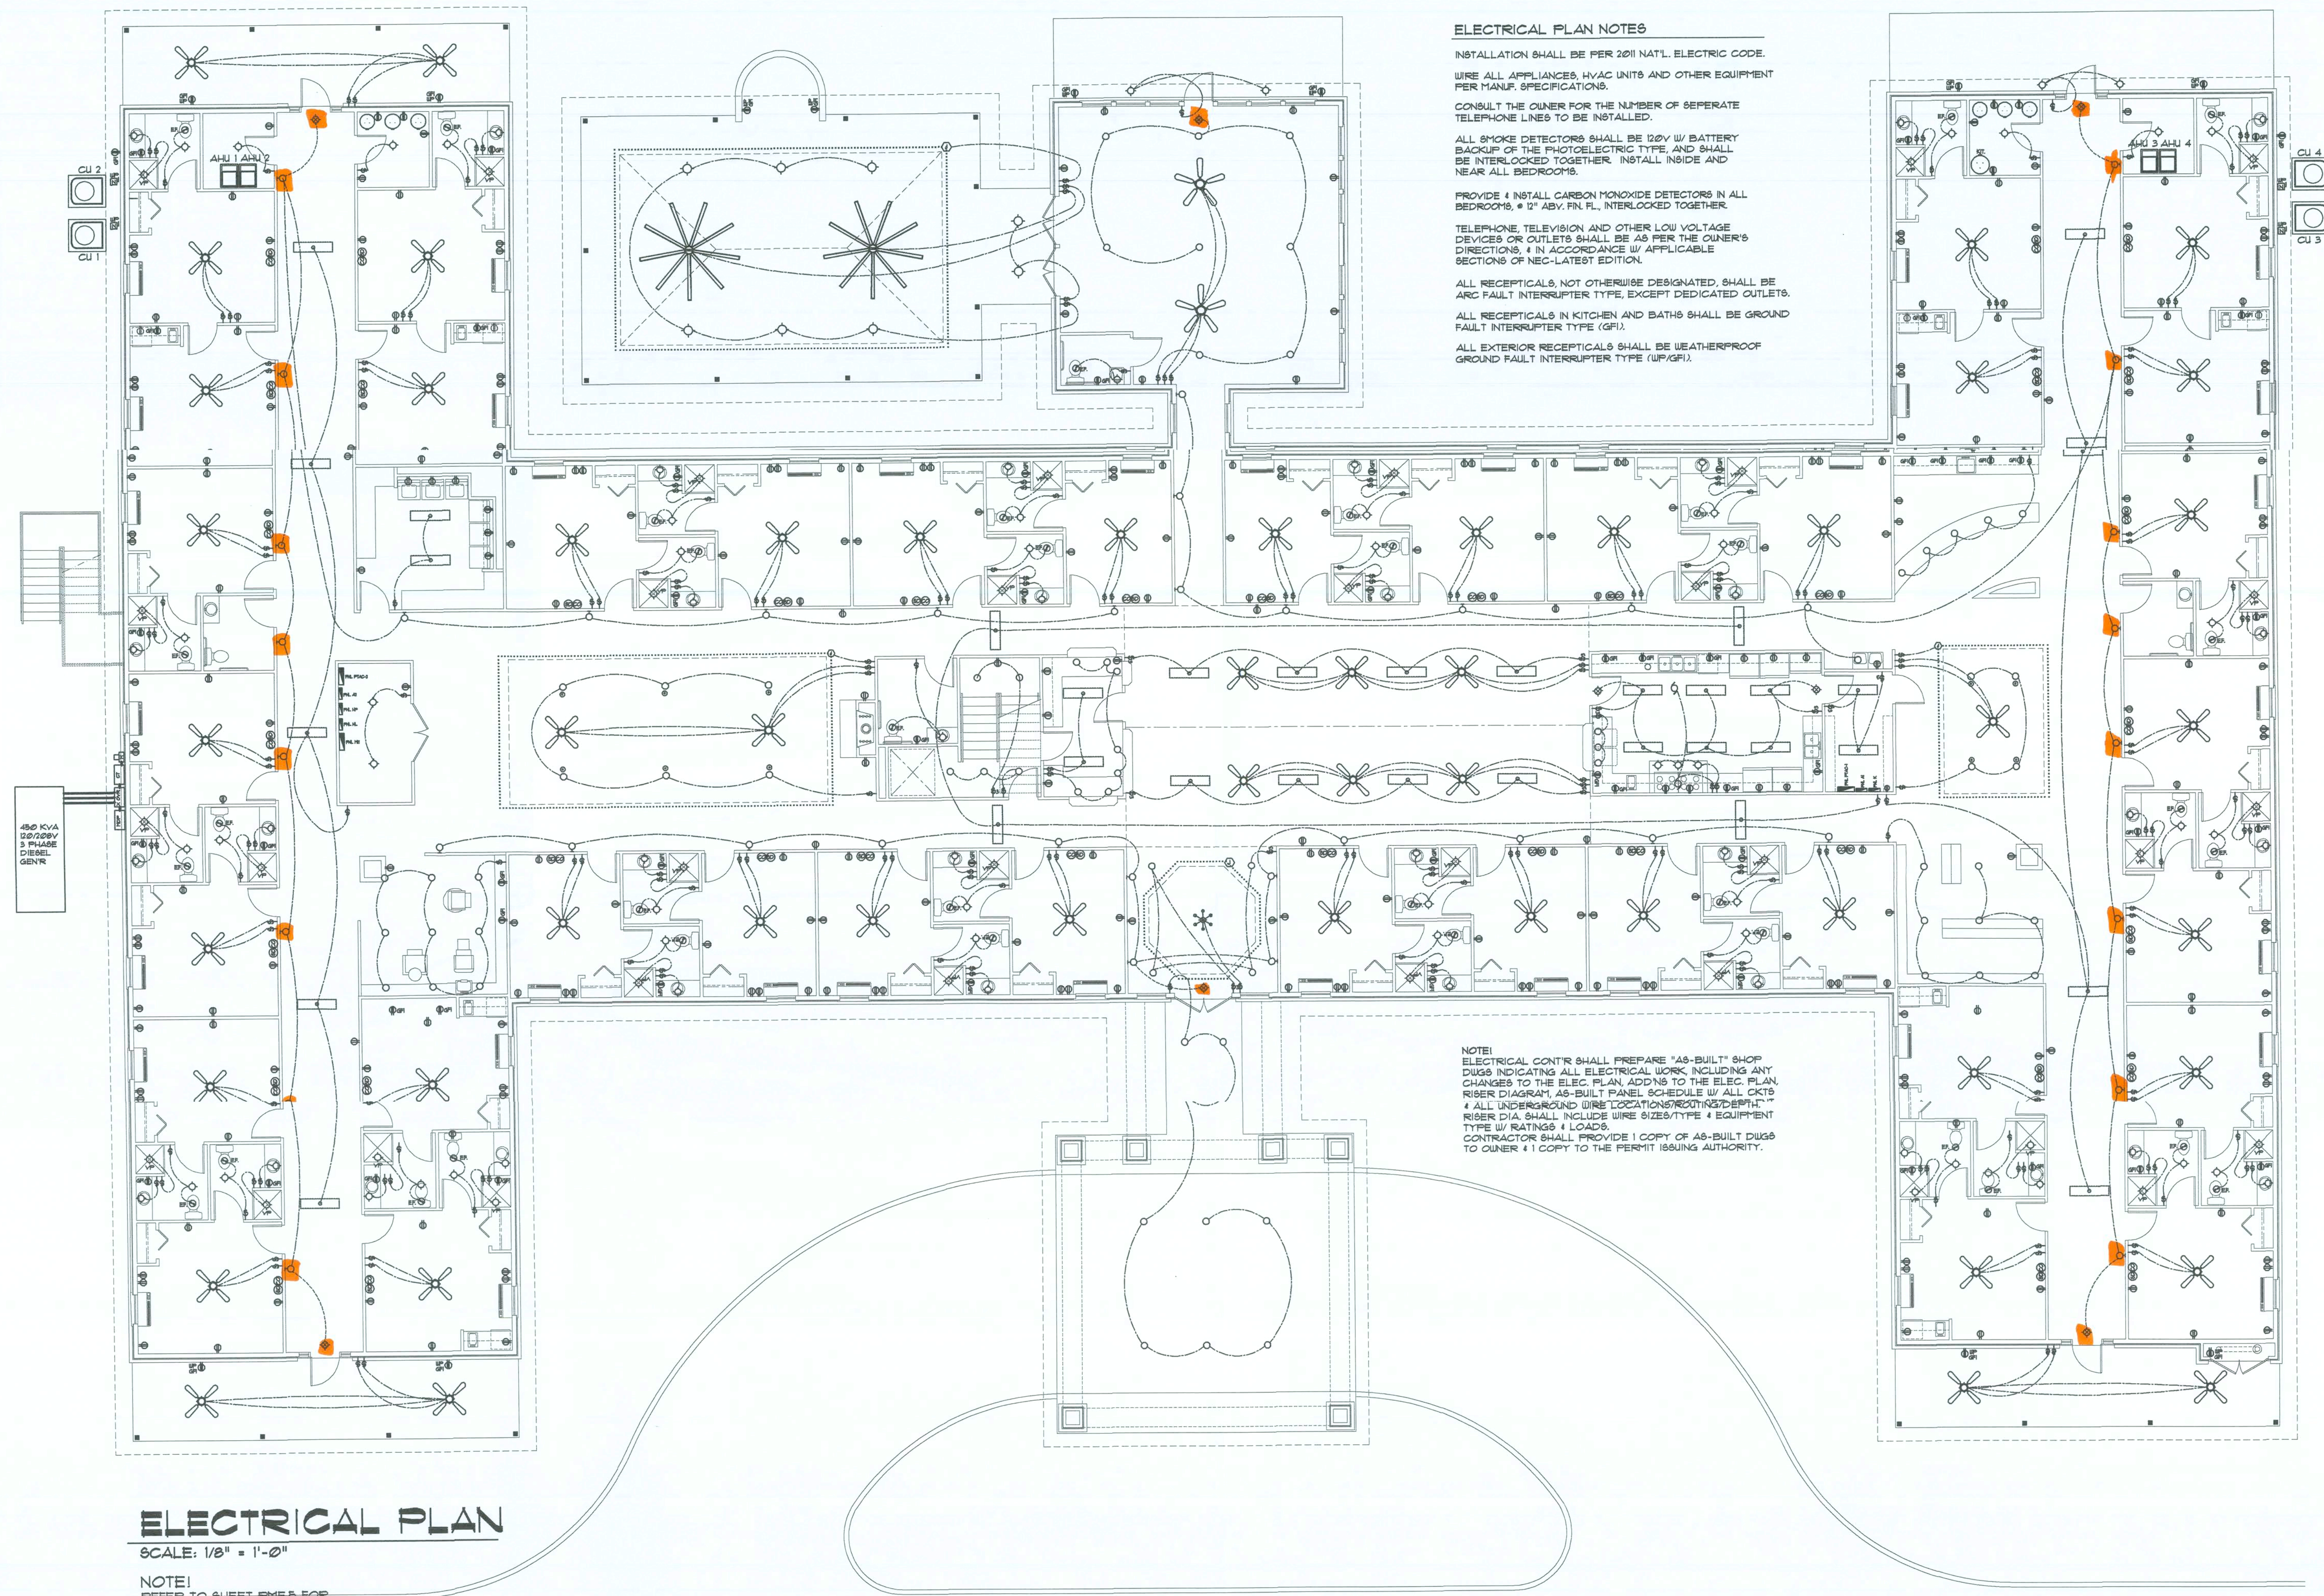

ELECTRICAL PLAN NOTES

INSTALLATION SHALL BE PER 2011 NAT'L. ELECTRIC CODE.

WIRE ALL APPLIANCES, HVAC UNITS AND OTHER EQUIPMENT PER MANUF. SPECIFICATIONS.

CONSULT THE OWNER FOR THE NUMBER OF SEPERATE TELEPHONE LINES TO BE INSTALLED.

ALL SMOKE DETECTORS SHALL BE 120V W/ BATTERY BACKUP OF THE PHOTOELECTRIC TYPE, AND SHALL BE INTERLOCKED TOGETHER. INSTALL INSIDE AND NEAR ALL BEDROOMS.

PROVIDE 4 INSTALL CARBON MONOXIDE DETECTORS IN ALL BEDROOMS, # 12" ABV. FIN. FL., INTERLOCKED TOGETHER.

TELEPHONE, TELEVISION AND OTHER LOW VOLTAGE DEVICES OR OUTLETS SHALL BE AS PER THE OWNER'S DIRECTIONS, & IN ACCORDANCE W/ APPLICABLE SECTIONS OF NEC-LATEST EDITION.

ALL RECEPTICALS, NOT OTHERWISE DESIGNATED, SHALL BE ARC FAULT INTERRUPTER TYPE, EXCEPT DEDICATED OUTLETS.

ALL RECEPTICALS IN KITCHEN AND BATHS SHALL BE GROUND FAULT INTERRUPTER TYPE (GFI).

ALL EXTERIOR RECEPTICALS SHALL BE WEATHERPROOF GROUND FAULT INTERRUPTER TYPE (WPGFI).

NOTE:
ELECTRICAL CONTR SHALL PREPARE "AS-BUILT" SHOP DWGS INDICATING ALL ELECTRICAL WORK, INCLUDING ANY CHANGES TO THE ELEC. PLAN, ADDING TO THE ELEC. PLAN, RISER DIAGRAM, AS-BUILT PANEL SCHEDULE W/ ALL CKTS & ALL UNDERGROUND WIRE LOCATIONS/ROUTING/DEPTH. RISER DIA. SHALL INCLUDE WIRE SIZES/TYPE & EQUIPMENT TYPE W/ RATINGS & LOADS. CONTRACTOR SHALL PROVIDE 1 COPY OF AS-BUILT DWGS TO OWNER & 1 COPY TO THE PERMIT ISSUING AUTHORITY.

ELECTRICAL PLAN
SCALE: 1/8" = 1'-0"

NOTE!
REFER TO SHEET PME.5 FOR ELECTRICAL SYMBOLS

REVISION:
02 SEP 2020

Copyright 2020
N.P. Geisler, Architect
DRAWN:
mpg

ASSISTED LIVING FACILITY for
SMITH - SORENSEN
LAKE CITY, COLUMBIA COUNTY, FLORIDA
ELECTRICAL PLAN

Celebrating
48 Years of Service
1972-2020
N.P. Geisler, Architect
AR0007005

NG
NICHOLAS
GEISLER
ARCHITECT
N.C.A.R.B. Certified
1758 NW 84th Rd.
Boca Raton, FL 33433-3551

DATE:
18 AUG 2020
CONTRACT:
2K2040

SHEET:
PME.6
6 of 7

Digitally signed by N.P. Geisler
DN: cn = N.P. Geisler, c = US
o = AR0007005, ou = ARCHITECT
Date: 2020.08.18 12:14:35-07

AR0007005

These drawings, as instruments of service, are the sole property of the architect, and may not be used, copied or reproduced in whole or in part for use on or incorporation into any other project without specific and individual authorization by the architect.

FNL "A1": 125A - MLO - 208/208V - 3P - BU WKA ALC - FLUSH - 42 SLOT												
CIR. N.	LOCATION	TRIP/POLES	WIRE SIZE	LOAD	#B KW	#C KW	LOAD	WIRE SIZE	TRIP/POLES	LOCATION	CIR. N.	
1	SUITE N-1	20A/1P	12U	1.66	3.12		1.66	12U	20A/1P	SUITE N-2	2	
2	SUITE N-3	"	"	1.66		3.12	1.66	"	"	SUITE N-4	3	
3	SUITE N-5	"	"	1.66			1.66	"	"	SUITE N-6	4	
4	SUITE N-7	"	"	1.66	3.12		3.12	1.66	"	SUITE N-8	5	
5	SUITE N-9	"	"	1.66		3.12	1.66	"	"	SUITE N-10	6	
6	SUITE N-11	"	"	1.66			1.66	"	"	SUITE N-12	7	
7	SUITE N-13	"	"	1.66	3.12		3.12	1.66	"	SUITE N-14	8	
8	SUITE N-15	"	"	1.66		3.12	1.66	"	"	SUITE N-16	9	
9	SUITE N-17	"	"	1.66			1.66	"	"	SUITE N-18	10	
10	SUITE N-19	"	"	1.66	3.12		3.12	1.66	"	SUITE N-20	11	
11	SUITE N-21	"	"	1.66			1.66	"	"	SUITE N-22	12	
12	SUITE N-23	"	"	0.54	1.08		0.54	"	"	SUITE N-24	13	
13	SUITE N-25	"	"	0.54		1.08	0.54	"	"	SUITE N-26	14	
14	SUITE N-27	"	"	0.54			0.54	"	"	SUITE N-28	15	
15	SUITE N-29	"	"	0.54	1.08		0.54	"	"	SUITE N-30	16	
16	SUITE N-31	"	"	0.54		1.08	0.54	"	"	SUITE N-32	17	
17	SUITE N-33	"	"	0.54			0.54	"	"	SUITE N-34	18	
18	SUITE N-35	"	"	0.54	1.08		0.54	"	"	SUITE N-36	19	
19	SUITE N-37	"	"	0.54		1.08	0.54	"	"	SUITE N-38	20	
20	SUITE N-39	"	"	0.54			0.54	"	"	SUITE N-40	21	
21	SUITE N-41	"	"	0.54	1.08		0.54	"	"	SUITE N-42	22	
22	SUITE N-43	"	"	0.54		1.08	0.54	"	"	SUITE N-44	23	
23	SUITE N-45	"	"	0.54			0.54	"	"	SUITE N-46	24	
24	SUITE N-47	"	"	0.54	1.08		0.54	"	"	SUITE N-48	25	
25	SUITE N-49	"	"	0.54		1.08	0.54	"	"	SUITE N-50	26	
26	SUITE N-51	"	"	0.54			0.54	"	"	SUITE N-52	27	
27	SUITE N-53	"	"	0.54	1.08		0.54	"	"	SUITE N-54	28	
28	SUITE N-55	"	"	0.54		1.08	0.54	"	"	SUITE N-56	29	
29	SUITE N-57	"	"	0.54			0.54	"	"	SUITE N-58	30	
30	SUITE N-59	"	"	0.54	1.08		0.54	"	"	SUITE N-60	31	
31	SUITE N-61	"	"	0.54		1.08	0.54	"	"	SUITE N-62	32	
32	SUITE N-63	"	"	0.54			0.54	"	"	SUITE N-64	33	
33	SUITE N-65	"	"	0.54	1.08		0.54	"	"	SUITE N-66	34	
34	SUITE N-67	"	"	0.54		1.08	0.54	"	"	SUITE N-68	35	
35	SUITE N-69	"	"	0.54			0.54	"	"	SUITE N-70	36	
36	SUITE N-71	"	"	0.54	1.08		0.54	"	"	SUITE N-72	37	
37	SUITE N-73	"	"	0.54		1.08	0.54	"	"	SUITE N-74	38	
38	SUITE N-75	"	"	0.54			0.54	"	"	SUITE N-76	39	
39	SUITE N-77	"	"	0.54	1.08		0.54	"	"	SUITE N-78	40	
40	SUITE N-79	"	"	0.54		1.08	0.54	"	"	SUITE N-80	41	
41	SUITE N-81	"	"	0.54			0.54	"	"	SUITE N-82	42	
42	SUITE N-83	"	"	0.54	1.08		0.54	"	"	SUITE N-84	43	
43	SUITE N-85	"	"	0.54		1.08	0.54	"	"	SUITE N-86	44	
44	SUITE N-87	"	"	0.54			0.54	"	"	SUITE N-88	45	
45	SUITE N-89	"	"	0.54	1.08		0.54	"	"	SUITE N-90	46	
46	SUITE N-91	"	"	0.54		1.08	0.54	"	"	SUITE N-92	47	
47	SUITE N-93	"	"	0.54			0.54	"	"	SUITE N-94	48	
48	SUITE N-95	"	"	0.54	1.08		0.54	"	"	SUITE N-96	49	
49	SUITE N-97	"	"	0.54		1.08	0.54	"	"	SUITE N-98	50	
50	SUITE N-99	"	"	0.54			0.54	"	"	SUITE N-100	51	
51	SUITE N-101	"	"	0.54	1.08		0.54	"	"	SUITE N-102	52	
52	SUITE N-103	"	"	0.54		1.08	0.54	"	"	SUITE N-104	53	
53	SUITE N-105	"	"	0.54			0.54	"	"	SUITE N-106	54	
54	SUITE N-107	"	"	0.54	1.08		0.54	"	"	SUITE N-108	55	
55	SUITE N-109	"	"	0.54		1.08	0.54	"	"	SUITE N-110	56	
56	SUITE N-111	"	"	0.54			0.54	"	"	SUITE N-112	57	
57	SUITE N-113	"	"	0.54	1.08		0.54	"	"	SUITE N-114	58	
58	SUITE N-115	"	"	0.54		1.08	0.54	"	"	SUITE N-116	59	
59	SUITE N-117	"	"	0.54			0.54	"	"	SUITE N-118	60	
60	SUITE N-119	"	"	0.54	1.08		0.54	"	"	SUITE N-120	61	
61	SUITE N-121	"	"	0.54		1.08	0.54	"	"	SUITE N-122	62	
62	SUITE N-123	"	"	0.54			0.54	"	"	SUITE N-124	63	
63	SUITE N-125	"	"	0.54	1.08		0.54	"	"	SUITE N-126	64	
64	SUITE N-127	"	"	0.54		1.08	0.54	"	"	SUITE N-128	65	
65	SUITE N-129	"	"	0.54			0.54	"	"	SUITE N-130	66	
66	SUITE N-131	"	"	0.54	1.08		0.54	"	"	SUITE N-132	67	
67	SUITE N-133	"	"	0.54		1.08	0.54	"	"	SUITE N-134	68	
68	SUITE N-135	"	"	0.54			0.54	"	"	SUITE N-136	69	
69	SUITE N-137	"	"	0.54	1.08		0.54	"	"	SUITE N-138	70	
70	SUITE N-139	"	"	0.54		1.08	0.54	"	"	SUITE N-140	71	
71	SUITE N-141	"	"	0.54			0.54	"	"	SUITE N-142	72	
72	SUITE N-143	"	"	0.54	1.08		0.54	"	"	SUITE N-144	73	
73	SUITE N-145	"	"	0.54		1.08	0.54	"	"	SUITE N-146	74	
74	SUITE N-147	"	"	0.54			0.54	"	"	SUITE N-148	75	
75	SUITE N-149	"	"	0.54	1.08		0.54	"	"	SUITE N-150	76	
76	SUITE N-151	"	"	0.54		1.08	0.54	"	"	SUITE N-152	77	
77	SUITE N-153	"	"	0.54			0.54	"	"	SUITE N-154	78	
78	SUITE N-155	"	"	0.54	1.08		0.54	"	"	SUITE N-156	79	
79	SUITE N-157	"	"	0.54		1.08	0.54	"	"	SUITE N-158	80	
80	SUITE N-159	"	"	0.54			0.54	"	"	SUITE N-160	81	
81	SUITE N-161	"	"	0.54	1.08		0.54	"	"	SUITE N-162	82	
82	SUITE N-163	"	"	0.54		1.08	0.54	"	"	SUITE N-164	83	
83	SUITE N-165	"	"	0.54			0.54	"	"	SUITE N-166	84	
84	SUITE N-167	"	"	0.54	1.08		0.54	"	"	SUITE N-168	85	
85	SUITE N-169	"	"	0.54		1.08	0.54	"	"	SUITE N-170	86	
86	SUITE N-171	"	"	0.54			0.54	"	"	SUITE N-172	87	
87	SUITE N-173	"	"	0.54	1.08		0.54	"	"	SUITE N-174	88	
88	SUITE N-175	"	"	0.54		1.08	0.54	"	"	SUITE N-176	89	
89	SUITE N-177	"	"	0.54			0.54	"	"	SUITE N-178	90	
90	SUITE N-179	"	"	0.54	1.08		0.54	"	"	SUITE N-180	91	
91	SUITE N-181	"	"	0.54		1.08	0.54	"	"	SUITE N-182	92	
92	SUITE N-183	"	"	0.54			0.54	"	"	SUITE N-184	93	
93	SUITE N-185	"	"	0.54	1.08		0.54	"	"	SUITE N-186	94	
94	SUITE N-187	"	"	0.54		1.08	0.54	"	"	SUITE N-188	95	
95	SUITE N-189	"	"	0.54			0.54	"	"	SUITE N-190	96	
96	SUITE N-191	"	"	0.54	1.08		0.54	"	"	SUITE N-192	97	
97	SUITE N-193	"	"	0.54		1.08	0.54	"	"	SUITE N-194	98	
98	SUITE N-195	"	"	0.54			0.54	"	"	SUITE N-196	99	
99	SUITE N-197	"	"	0.54	1.08		0.54	"	"	SUITE N-198	100	
100	SUITE N-199	"	"	0.54		1.08	0.54	"	"	SUITE N-200	101	
101	SUITE N-201	"	"	0.54			0.54	"	"	SUITE N-202	102	
102	SUITE N-203	"	"	0.54	1.08		0.54	"	"	SUITE N-204	103	
103	SUITE N-205	"	"	0.54		1.08	0.54	"	"	SUITE N-206	104	
104	SUITE N-207	"	"	0.54			0.54	"	"	SUITE N-208	105	
105	SUITE N-209	"	"	0.54	1.08		0.54	"	"	SUITE N-210	106	
106	SUITE N-211	"	"	0.54		1.08	0.54	"	"	SUITE N-212	107	
107	SUITE N-213	"	"	0.54			0.54	"	"	SUITE N-214	108	
108	SUITE N-215	"	"	0.54	1.08		0.54	"	"	SUITE N-216	109	
109	SUITE N-217	"	"	0.54		1.08	0.54	"	"	SUITE N-218	110	
110	SUITE N-219	"	"	0.54			0.54	"	"	SUITE N-220	111	
111	SUITE N-221	"	"	0.54	1.08		0.54	"	"	SUITE N-222	112	
112	SUITE N-223	"	"	0.54		1.08	0.54	"	"	SUITE N-224	113	
113	SUITE N-225	"	"	0.54			0.54	"	"	SUITE N-226	114	
114	SUITE N-227	"	"	0.54	1.08		0.54	"	"	SUITE N-228	115	
115	SUITE N-229	"	"	0.54		1.08	0.54	"	"	SUITE N-230	116	
116	SUITE N-231	"	"	0.54			0.54	"	"	SUITE N-232	117	
117	SUITE N-233	"	"	0.54	1.08		0.54	"	"	SUITE N-234	118	
118	SUITE N-235	"	"	0.54		1.08	0.54	"	"	SUITE N-236	119	
119	SUITE N-237	"	"	0.54			0.54	"	"	SUITE N-238	120	
120	SUITE N-239	"	"	0.54	1.08		0.54	"	"	SUITE N-240	121	
121	SUITE N-241	"	"	0.54		1.08	0.54	"	"	SUITE N-242	122	
122	SUITE N-243	"	"	0.54			0.54	"	"	SUITE N-244	123	
123	SUITE N-245	"	"	0.54	1.08		0.54	"	"	SUITE N-246	124	
124	SUITE N-247	"	"	0.54		1.08	0.54	"	"	SUITE N-248	125	
125	SUITE N-249	"	"	0.54			0.54	"	"	SUITE N-250	126	
126	SUITE N-251	"	"	0.54	1.08		0.54	"	"	SUITE N-252	127	
127	SUITE N-253	"	"	0.54		1.08	0.54	"	"	SUITE N-254	128	
128	SUITE N-255	"	"	0.54			0.54	"	"	SUITE N-256	129	
129	SUITE N-257	"	"	0.54	1.08		0.54	"	"	SUITE N-258	130	
130	SUITE N-259	"	"	0.54		1.08	0.54	"	"	SUITE N-260	131	
131	SUITE N-261	"	"	0.54			0.54	"	"	SUITE N-262	132	
132	SUITE N-263	"	"	0.54	1.08		0.54	"	"	SUITE N-264	133	
133	SUITE N-265	"	"	0.54		1.08	0.54	"	"	SUITE N-266	134	
134	SUITE N-267	"	"	0.54			0.54	"	"	SUITE N-268	135	
135	SUITE N-26											

FNL "PTAC-1": 400A - MLO - 120/208V - 3P - BU WKA ALC - FLUSH - 42 SLOT													
CIR. N.	LOCATION	TRIP/ POLES	WIRE SIZE	LOAD	KA KW	KB KW	CC KW	LOAD	WIRE SIZE	TRIP/ POLES	LOCATION	CIR. N.	
1	SUITE N-1 PTAC W CIR N-1	20A/1P	12U	1.66	3.60	3.60	1.66	1.66	12U	20A/1P	SUITE N-2 PTAC W R N-2	2	
2	SUITE N-2 PTAC W CIR N-2	"	"	1.66	"	"	1.66	"	"	"	SUITE N-3 PTAC W R N-3	3	
3	SUITE N-3 PTAC W CIR N-3	"	"	1.66	"	3.60	1.66	1.66	"	"	W R N-6	6	
4	SUITE N-4 PTAC W CIR N-4	"	"	1.66	"	3.60	1.66	1.66	"	"	SUITE N-5 PTAC W R N-5	5	
5	SUITE N-5 PTAC W CIR N-5	"	"	1.66	"	3.60	1.66	1.66	"	"	W R N-6	10	
6	SUITE N-6 PTAC W CIR N-6	"	"	1.66	3.60	3.60	1.66	1.66	"	"	SUITE N-7 PTAC W R N-7	7	
7	SUITE N-7 PTAC W CIR N-7	"	"	1.66	"	3.60	1.66	1.66	"	"	W R N-4	11	
8	SUITE N-8 PTAC W CIR N-8	"	"	1.66	"	3.60	1.66	1.66	"	"	SUITE N-9 PTAC W R N-9	9	
9	SUITE N-9 PTAC W CIR N-9	"	"	1.66	3.60	3.60	1.66	1.66	"	"	SUITE N-10 PTAC W R N-10	10	
10	SUITE N-10 PTAC W CIR N-10	"	"	1.66	"	3.60	1.66	1.66	"	"	W R N-11	11	
11	SUITE N-11 PTAC W CIR N-11	"	"	1.66	"	3.60	1.66	1.66	"	"	SUITE N-12 PTAC W R N-12	12	
12	SUITE N-12 PTAC W CIR N-12	"	"	1.66	3.60	3.60	1.66	1.66	"	"	SUITE N-13 PTAC W R N-13	13	
13	SUITE N-13 PTAC W CIR N-13	"	"	1.66	"	3.60	1.66	1.66	"	"	W R N-14	14	
14	SUITE N-14 PTAC W CIR N-14	"	"	1.66	"	3.60	1.66	1.66	"	"	SUITE N-15 PTAC W R N-15	15	
15	SUITE N-15 PTAC W CIR N-15	"	"	1.66	3.60	3.60	1.66	1.66	"	"	SUITE N-16 PTAC W R N-16	16	
16	SUITE N-16 PTAC W CIR N-16	"	"	1.66	"	3.60	1.66	1.66	"	"	W R N-17	17	
17	SUITE N-17 PTAC W CIR N-17	"	"	1.66	"	3.60	1.66	1.66	"	"	SUITE N-18 PTAC W R N-18	18	
18	SUITE N-18 PTAC W CIR N-18	"	"	1.66	3.60	3.60	1.66	1.66	"	"	SUITE N-19 PTAC W R N-19	19	
19	SUITE N-19 PTAC W CIR N-19	"	"	1.66	"	3.60	1.66	1.66	"	"	W R N-20	20	
20	SUITE N-20 PTAC W CIR N-20	"	"	1.66	"	3.60	1.66	1.66	"	"	SUITE N-21 PTAC W R N-21	21	
21	SUITE N-21 PTAC W CIR N-21	"	"	1.66	3.60	3.60	1.66	1.66	"	"	SUITE N-22 PTAC W R N-22	22	
22	SUITE N-22 PTAC W CIR N-22	"	"	1.66	"	3.60	1.66	1.66	"	"	W R N-23	23	
23	SUITE N-23 PTAC W CIR N-23	"	"	1.66	"	3.60	1.66	1.66	"	"	SUITE N-24 PTAC W R N-24	24	
24	SUITE N-24 PTAC W CIR N-24	"	"	1.66	3.60	3.60	1.66	1.66	"	"	SUITE N-25 PTAC W R N-25	25	
25	SUITE N-25 PTAC W CIR N-25	"	"	1.66	"	3.60	1.66	1.66	"	"	W R N-26	26	
26	SUITE N-26 PTAC W CIR N-26	"	"	1.66	"	3.60	1.66	1.66	"	"	SUITE N-27 PTAC W R N-27	27	
27	SUITE N-27 PTAC W CIR N-27	"	"	1.66	3.60	3.60	1.66	1.66	"	"	SUITE N-28 PTAC W R N-28	28	
28	SUITE N-28 PTAC W CIR N-28	"	"	1.66	"	3.60	1.66	1.66	"	"	W R N-29	29	
29	SUITE N-29 PTAC W CIR N-29	"	"	1.66	"	3.60	1.66	1.66	"	"	SUITE N-30 PTAC W R N-30	30	
30	SUITE N-30 PTAC W CIR N-30	"	"	1.66	3.60	3.60	1.66	1.66	"	"	SUITE N-31 PTAC W R N-31	31	
31	SUITE N-31 PTAC W CIR N-31	"	"	1.66	"	3.60	1.66	1.66	"	"	W R N-32	32	
32	SUITE N-32 PTAC W CIR N-32	"	"	1.66	"	3.60	1.66	1.66	"	"	SUITE N-33 PTAC W R N-33	33	
33	SUITE N-33 PTAC W CIR N-33	"	"	1.66	3.60	3.60	1.66	1.66	"	"	SUITE N-34 PTAC W R N-34	34	
34	SUITE N-34 PTAC W CIR N-34	"	"	1.66	"	3.60	1.66	1.66	"	"	W R N-35	35	
35	SUITE N-35 PTAC W CIR N-35	"	"	1.66	"	3.60	1.66	1.66	"	"	SUITE N-36 PTAC W R N-36	36	
36	SUITE N-36 PTAC W CIR N-36	"	"	1.66	3.60	3.60	1.66	1.66	"	"	SUITE N-37 PTAC W R N-37	37	
37	SUITE N-37 PTAC W CIR N-37	"	"	1.66	"	3.60	1.66	1.66	"	"	W R N-38	38	
38	SUITE N-38 PTAC W CIR N-38	"	"	1.66	"	3.60	1.66	1.66	"	"	SUITE N-39 PTAC W R N-39	39	
39	SUITE N-39 PTAC W CIR N-39	"	"	1.66	3.60	3.60	1.66	1.66	"	"	SUITE N-40 PTAC W R N-40	40	
40	SUITE N-40 PTAC W CIR N-40	"	"	1.66	"	3.60	1.66	1.66	"	"	W R N-41	41	
41	SUITE N-41 PTAC W CIR N-41	"	"	1.66	"	3.60	1.66	1.66	"	"	SUITE N-42 PTAC W R N-42	42	
42	SUITE N-42 PTAC W CIR N-42	"	"	1.66	3.60	3.60	1.66	1.66	"	"	W R N-43	43	

FEEDER SIZE: 3 x 250 MCM - THW - CU L x 3/4" x THW - CU - NAVL.

1 x 1/2" x 1/2

FNL "HL": 100A - MLO - 120/208V - 3P - BU WKA ALC - FLUSH - 42 SLOT													
CIR. N.	LOCATION	TRIP/ POLES	WIRE SIZE	LOAD	KA KW	KB KW	CC KW	LOAD	WIRE SIZE	TRIP/ POLES	LOCATION	CIR. N.	
1	LOBBY CHAND.	20A/1P	12U	0.60	1.20			0.43	12U	20A/1P	MECHN LITG	2	
2	LOBBY CHAND.	"	"	0.11		0.37		0.21	"	"	STORAGE RM. LITG	3	
3	LOBBY ROPE LITG	"	"	0.31			0.36	0.48	"	"	DINING CLG FANS	4	
4	PASSAGE SCENCE	"	"	0.28	1.18			0.44	"	"	DINING CLG FANS	5	
5	PASSAGE SCENCE	"	"	0.23			0.61	0.44	"	"	DINING CLG FANS	6	
6	PASSAGE SCENCE	"	"	0.23				0.44	"	"	LAUNDRY LITG	7	
7	VIEW ROPE LITG	"	"	0.98	1.22			0.24	"	"	BEATY SHOP LITG	8	
8	VIEW CLG FANS	"	"	0.72	0.4	0.34		0.27	"	"	LIBRARY LITG	9	
9	READS ROPE LITG	"	"	0.72	0.4	1.12		0.27	"	"	COFFEE SHOP LITG	10	
10	READS CLG FANS	"	"	0.72	0.4	0.43		0.32	"	"	HALLREST ROOM	11	
11	ACTIVITY RP. LITG	"	"	0.11			0.32	0.32	"	"	HALLREST ROOM	12	
12	ACTIVITY CLG FANS	"	"	0.11			0.32	0.32	"	"	ACTV REST ROOM	13	
13	ENTRY DRIVE LITG	"	"	0.16	0.20	1.35		0.64	"	"	OFF REST ROOMS	14	
14	PORCL CLG FANS	"	"	0.12			0.34	0.64	"	"	HALL OFFICE REST	15	
15	PORCL CLG FANS	"	"	0.12		1.35		0.67	"	"	PASSAGE / RVR	16	
16	SPARE	"	"	0.72	1.28	1.28		0.54	"	"	PAVILION LITG	17	
17	SPARE	"	"	0.72	0.34	0.34		0.54	"	"	SPARE	18	
18	SPARE	"	"	0.72	0.34	1.28		0.54	"	"	SPARE	19	
19	SPARE	"	"	0.72	0.34	0.34		0.54	"	"	SPARE	20	
20	SPARE	"	"	0.72	0.34	0.34		0.54	"	"	SPARE	21	
21	SPARE	"	"	0.72	0.34	0.34		0.54	"	"	SPARE	22	
131	SPARE	"	"	0.72	0.34	0.34		0.54	"	"	SPARE	132	
132	SPARE	"	"	0.72	0.34	0.34							