
SHEET NUMBER

A.8

OF 9 SHEETS

N. P.
GEISLER

Digitally signed by: N. P. GEISLER
DN: CN = N. P. GEISLER email =
npgeisle(47@gmail.com C = US O =
ARCHITECT OU = AR0007005
Date: 2024.04.04 10:51:50 -05'00'

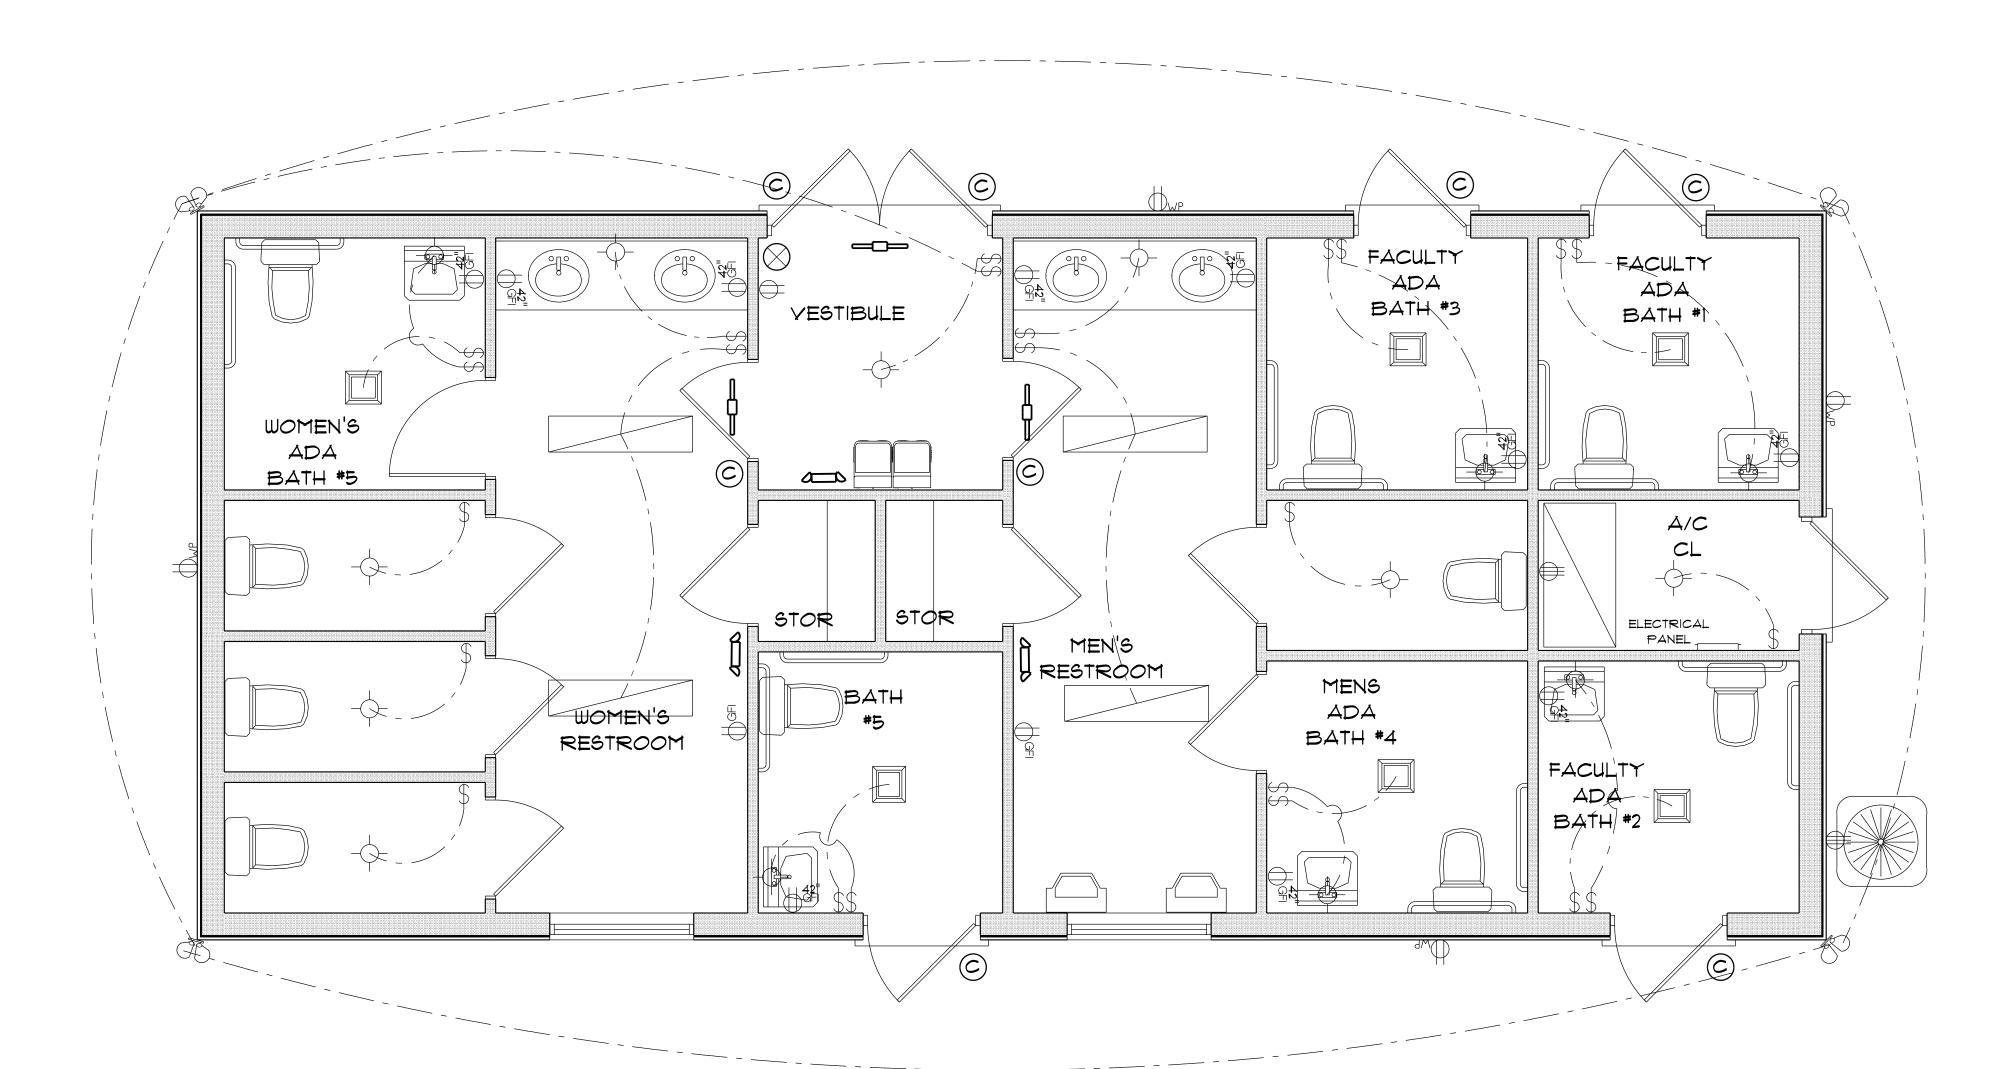

## \* ELECTRICAL PLAN \* SCALE: 3/8" = 1'=0"

## ELECTRICAL PLAN NOTES

**ELECTRICAL LEGEND** 

COUNT

14

2

12

23

**ELECTRICAL** 

fluorescent light 1 x 4

spotlight double

electrical panel

outlet 220v

outlet gfi

outlet wp

switch

combination fan and light-square 6

**SYMBOL** 

# GFI

- E-I WIRE ALL APPLIANCES, HYAC UNITS AND OTHER EQUIPMENT PER MANUFACTORS SPECIFICATIONS.
- E-2 CONSULT THE OWNER FOR THE NUMBER OF SEPERATE TELEPHONE LINES TO BE INSTALLED.
- E-3 ALL INSTALLATIONS SHALL BE PER NATIONAL ELECTRIC CODE.
- E-4

  ALL SMOKE DETECTORS SHALL BE 120Y W/BATTERY BACKUP
  OF THE PHOTOELECTRIC TYPE, AND SHALL BE INTERLOCKED
  TOGETHER. INSTALL INSIDE AND NEAR ALL BEDROOMS.
- E-5

  TELEPHONE, TELEVISION AND OTHER LOW YOLTAGE DEVICES
  OR OUTLETS SHALL BE AS PER THE OWNERS DIRECTION AND IN
  ACCORDANCE WITH APPLICABLE SECTIONS OF NATIONAL ELCT.
  CODE LATEST EDITION.
- E-6 ELECTRICAL CONTRACTOR SHALL BE RESPONSIBLE FOR THE DESIGN AND SIZING OF ELECTRICAL SERVICE AND CIRCUITS.
- E-7 ENTRY OF SERVICE UNDERGROUND OR OVERHEAD) IS TO BE DETERMINED BY THE POWER COMPANY.

## LEGEND

EXIT LIGHT - ARROW

REPRESENTS DIRECTION

OF EXIT

WALL HUNG "ABC" FIRE EXTINGUISHER

DOOR / CLOSWER FOR EXITING
OR RATING REASONS

EMERGENCY LIGHT
W/ BATTERY BACKUP

NOTE

EMERGENCY LIGHTING AND EXIT SIGNS, SHALL BE PROVIDED AS DIRECTED BY THE FIRE MARSHAL, AND SHALL BE WIRED PER NEC 700-12F