


P:\Projects\414-0210.038_(TA38)_Ichetucknee_Restroom\CADD\14-0210.038_(TA38)_COVER.dwg

ABBREVIATIONS

A.F.F.	ABOVE FINISHED FLOOR
A.H.U.	AIR HANDLING UNIT
ALUM.	ALUMINUM
ALT.	ALTERNATE
APPROX.	APPROXIMATE
B.O.	BOARD
B.L.D.G.	BUILDING
B.L.K.	BLOCK
B.L.K.G.	BLOCKING
B.L.T.	BUILT
BRCK.	BRICK
BRKR.	BREAKER
BSMT.	BASEMENT
C.J.	CONTROL JOINT
C.L.G.	CEILING
C.R.	CLEAR
CMU	CONCRETE MASONRY UNIT
C.O.	CLEAN OUT
CONC.	CONCRETE
COP.	COPPER
CU. FT.	CUBIC FOOT
CU. IN.	CUBIC INCH
CU. YD.	CUBIC YARD
DA./#	DIAMETER
DBL	DOUBLE
DET.	DETACH
DRY-BULB	DRY-BULB TEMPERATURE
DEG.	DEGREE
DEPT.	DEPTH
DEPT.	DEPARTMENT
DISC.	DISCONNECT
DR.	DRINKING FOUNTAIN
DISC.	DISCONNECT
DL	DEAD LOAD
DN.	DOWN
D.S.	DOWN SPOUT
DWG.	DRAWING
E.F.	EXHAUST FAN
EXH.	EXHAUST
EXP.	EXPANSION JOINT
EXT.	EXTERIOR
FIN.	FINISH
FL.	FLOOR
FLUOR.	FLUORESCENT
FR.	FIRE RATING
FT.	FOOT/FEET
FTG.	FOOTING
GALV.	GALVANIZED
GFI	GROUND FAULT
GFI	CIRCUIT INTERRUPT
GOVT.	GOVERNMENT
GR.FL.	GROUND FLOOR
GYP.	GYPSUM
H.C.	HOLLOW CORE
H.D.G.	HOT DIPPED GALVANIZED
HDR.	HEADER
HDWR.	HARDWARE
H.P.	HORSEPOWER
HT.	HEIGHT
HTR.	HEATER
HVAC	HIGH VOLTAGE
HVAC	HEATING, VENTILATING
HVAC	AND AIR CONDITIONING
Hwy.	HIGHWAY
ID.	INSIDE DIAMETER
IN.	INCH
INCAND.	INCANDESCENT
INCL.	INCLUDED
INSUL.	INSULATION
INT.	INTERIOR
INV. EL.	INVERT ELEVATION
JST.	JOIST
KD.	KILN DRIED
KW	KILOWATT
KWH	KILOWATT HOUR
LAM.	LAMINATED
LAV.	LAVATORY
LB.	POUND
LTC.	LIGHTING
LGTH.	LENGTH
LIN.	LINEAR
LL	LIVE LOAD
MANUF.	MANUFACTURE
MAX.	MAXIMUM
MF.	MILL FINISH
MIN.	MINIMUM
MLDG.	MOLDING
MHW	MEAN HIGH WATER
MHHW	MEAN HIGHER HIGH WATER
MHW	MEAN HIGH WATER
MLW	MEAN LOWER LOW WATER
MLW	MEAN LOWER LOW WATER
MOD.	MODIFICATION
MOD.	MODIFICATION
NTS	NOT TO SCALE
NO./#	NUMBER
O.C.	OVERALL
O.C.	ON CENTER
O.D.	OUTSIDE DIAMETER
OFC.	OFFICE
O/H	OVER HEAD
OPP.	OPPOSITE
PARTIAL	PARTITION
PC	PORTLAND CEMENT
PSF	POUNDS PER SQUARE FOOT
P.E.	PROFESSIONAL ENGINEER
PERF.	PERFORATE
PERP.	PERPENDICULAR
PLG.	PLATE
PLG.	PLUG
PLYWD.	PLYWOOD
PNL	PANEL
PREFAB.	PREFABRICATED
PRELIM.	PRELIMINARY
PSF	POUNDS PER SQUARE FOOT
PSI	POUNDS PER SQUARE INCH
P.T.	PRESSURE TREATED
OS	QUARTER SAWN
R	RADIUS
R.F.P.T.	REINFORCING BAR
REBAR	REINFORCING BAR
REFRIG.	REFRIGERATION
REIN.	REINFORCING
RFG.	ROOFING
RSH	ROUGH
RM	ROOM
R.O.	ROUGH OPENING
RS	ROUGH SAWN
S.C.	SOLID CORE
SCH.	SCHEDULE
SCH.	SCHED
SECT.	SECTION
SECT.	SECTION
SLDNG	SLIDING GLASS DOOR
SH.	SHINGLES
SPEC.	SPECIFICATION
SPR.	SPIRZE
SQ.	SQUARE
SQ. FT.	SQUARE FOOT
SQ. IN.	SQUARE INCH
SQ. YD.	SQUARE YARD
SS	STAINLESS STEEL
STL	STEEL
SUB. FL.	SUBFLOOR
SUP.	SUPPLY
SW.	SWITCH
SYM.	SYMMETRICAL
S.Y.P.	SOUTHERN YELLOW PINE
SYS.	SYSTEM
SURF.	SURFACED FOUR SIDES
TEL.	TELEPHONE
T&G	TONGUE-AND-GROOVE
TYP.	TYPICAL
U.E.	UNDERGROUND ELECTRIC
U.G.	UNDER GROUND
UL	UNDERWRITERS
LABORATORIES, INC.	
V.	VOLT
VENT.	VENTILATOR
VERT.	VERTICAL
VF.	VERIFY IN FIELD
VOL.	VOLUME
VP	VENT PIPE
VTR.	VENT THRU ROOF
W.	WATER
WBT.	WET BULB TEMPERATURE
WC	WATER CLOSET
WD.	WOOD
WP	WATERPROOF
WTF.	WELDED WIRE FABRIC
YD	YARD

REFERENCE LEGEND

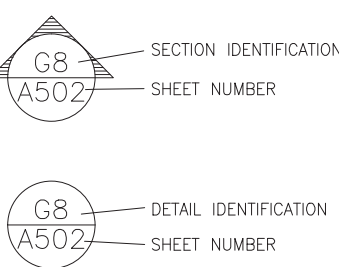

ICHETUCKNEE SPRINGS STATE PARK

DISTRICT 2

COLUMBIA COUNTY

REPLACE RESTROOM

FDEP PROJECT # 61363C

SITE ADDRESS: 12087 SOUTHWEST U.S. 27
FORT WHITE, FL 32038

APPLICABLE CODES AND DESIGN DATA

CODE LIST

FLORIDA BUILDING CODE, BUILDING (FBC-B).....	2020 Edition
FLORIDA BUILDING CODE, FUEL GAS (FBC-FG).....	2020 Edition
FLORIDA BUILDING CODE, MECHANICAL (FBC-M).....	2020 Edition
FLORIDA BUILDING CODE, PLUMBING (FBC-P).....	2020 Edition
FLORIDA BUILDING CODE, EXISTING BUILDING (FBC-EB).....	2020 Edition
FLORIDA BUILDING CODE, RESIDENTIAL (FBC-R).....	2020 Edition
FLORIDA FIRE PREVENTION CODE (FFPC).....	2020 Edition
NATIONAL ELECTRICAL CODE NFPA-70.....	2017 Edition
FDOT STANDARD SPECIFICATIONS FOR ROAD & BRIDGE CONST.	Latest Edition
FDOT DESIGN STANDARDS.....	Latest Edition
FLORIDA ACCESSIBILITY CODE.....	2020 Edition

DESIGN DATA

CONSTRUCTION TYPE: TYPE II-B NON SPRINKLERED	TOTAL BUILDING AREA PER FLOOR: 1,115 GSF
OCCUPANCY CLASS: FBC GROUP B BUSINESS	BUILDING HEIGHT/NUMBER OF STORIES: 1
OCCUPANT LOAD: 10 PERSONS	REQUIRED SPRINKLER OR ALARM SYSTEM: No
TOTAL EXITS: N/A	NUMBER OF BEDROOMS: N/A
SQ FT ALTERED AREA N/A	LEVEL OF ALTERATION: N/A


DESIGN LOADS (FBC-B CHAPTER 16):
20 PSF

WIND LOADS (FBC-B SECTION 1609):
120 MPH

DRMP
DESIGNER

CN225
CONSULTANT CONTRACT NO.

8/7/2023
INITIAL ISSUE DATE

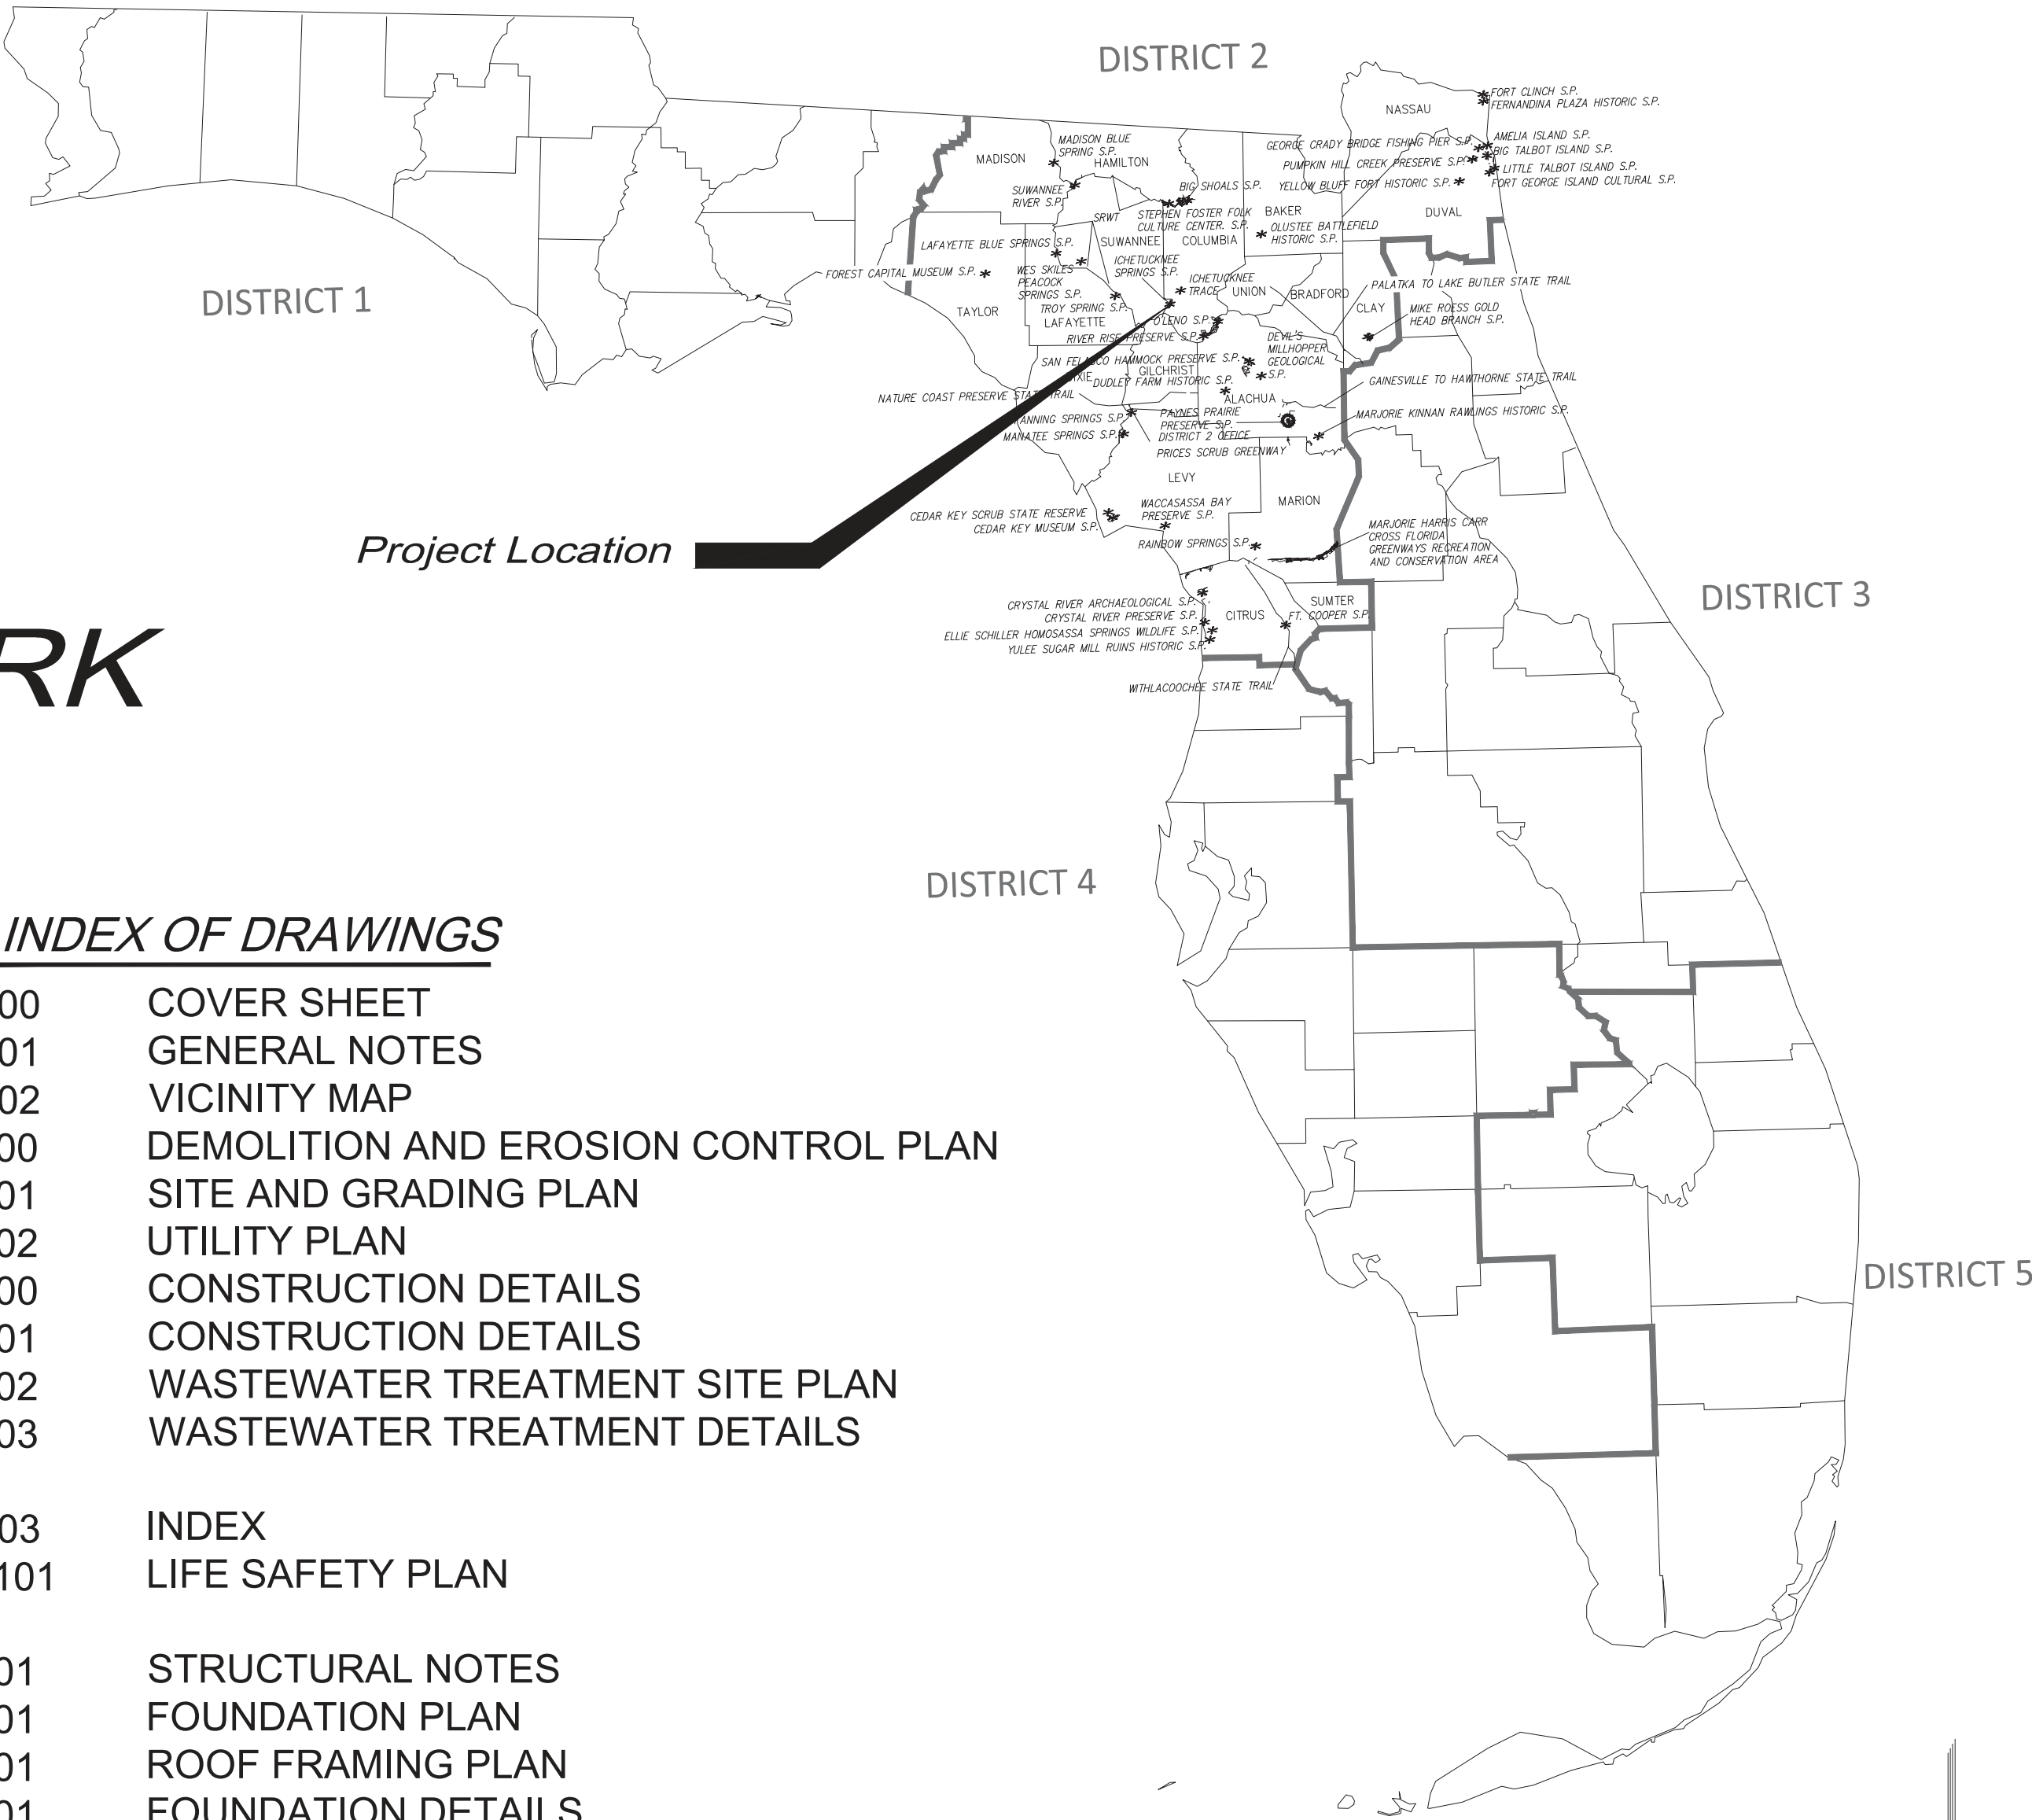

INDEX OF DRAWINGS

G100	COVER SHEET
G101	GENERAL NOTES
G102	VICINITY MAP
C100	DEMOLITION AND EROSION CONTROL PLAN
C101	SITE AND GRADING PLAN
C102	UTILITY PLAN
C200	CONSTRUCTION DETAILS
C201	CONSTRUCTION DETAILS
C202	WASTEWATER TREATMENT SITE PLAN
C203	WASTEWATER TREATMENT DETAILS

G103	INDEX
LS101	LIFE SAFETY PLAN

S001	STRUCTURAL NOTES
S101	FOUNDATION PLAN
S201	ROOF FRAMING PLAN
S301	FOUNDATION DETAILS
S302	TYPICAL BUILDING SECTION
S401	TYPICAL MASONRY DETAILS

A100	ARCHITECTURAL SPECIFICATIONS
A101	RESTROOM BUILDING - FLOOR PLAN
A102	RESTROOM BUILDING - FLOOR PLAN - PLUMBING
A201	RESTROOM BUILDING - REFLECTED CEILING PLAN
A301	RESTROOM BUILDING - BUILDING ELEVATIONS
A401	RESTROOM BUILDING - BUILDING & WALL SECTIONS
A501	RESTROOM BUILDING - ROOF PLAN


M001	LEGEND, NOTES & SCHEDULES - HVAC
M101	FLOOR PLANS - MECHANICAL
M501	DETAILS - MECHANICAL

P001	LEGEND, NOTES, DETAILS & SCHEDULES - PLUMBING
P101	FLOOR PLANS - PLUMBING
P501	DETAILS & SCHEDULES - PLUMBING
P601	ISOMETRICS - PLUMBING

E001	LEGEND & NOTES - ELECTRICAL
E100	SITE PLAN - ELECTRICAL
E101	FLOOR PLANS - ELECTRICAL
E701	PANEL SCHEDULES - ELECTRICAL

THIS ITEM HAS BEEN DIGITALLY SIGNED
AND SEALED BY:

Digitally signed
by Benjamin R
Lennon
Date:
2023.08.14
11:20:25-04'00'

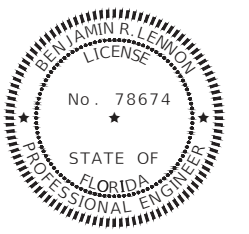

ON THE DATE ADJACENT TO THE SEAL.
PRINTED COPIES OF THIS DOCUMENT
ARE NOT CONSIDERED SIGNED AND
SEALED AND THE SIGNATURE MUST BE
VERIFIED ON ANY ELECTRONIC COPIES.
THE ABOVE NAMED PROFESSIONAL ENGINEER SHALL BE
RESPONSIBLE FOR THE FOLLOWING SHEETS IN
ACCORDANCE WITH RULE 61G15-23.004, F.A.C.:

G100	COVER SHEET
G101	GENERAL NOTES
G102	VICINITY MAP
C100	DEMOLITION AND EROSION CONTROL PLAN
C101	SITE AND GRADING PLAN
C102	UTILITY PLAN
C200	CONSTRUCTION DETAILS
C201	CONSTRUCTION DETAILS



P:\Projects\14\14-0210.038_(TA38)_Ichetucknee_Restroom\CADD\14-0210.038_(TA38)_NOTES.dwg Plotted: Aug. 14, 2023 - 11:12am by Blennon

GENERAL NOTES:

1. UNLESS OTHERWISE NOTED, ALL WORK SHALL BE PERFORMED CONSISTENT WITH FDOT DESIGN STANDARDS (LATEST EDITION) AND THE FDOT STANDARD SPECIFICATIONS FOR ROAD AND BRIDGE CONSTRUCTION (LATEST EDITION).
2. IF CONTRACTOR OR THEIR SUBCONTRACTORS DO NOT COMPLY WITH THE REQUIREMENTS OF THESE GENERAL NOTES, SPECIFICATIONS OR AGREEMENT BETWEEN OWNER AND CONTRACTOR, OWNER MAY, BUT IS NOT REQUIRED TO, GIVE WRITTEN NOTICE OF VIOLATION TO CONTRACTOR. SHOULD CONTRACTOR OR ITS SUBCONTRACTORS FAIL TO COMPLY WITH REQUIREMENTS OF THESE GENERAL NOTES WITHIN TWENTY-FOUR (24) HOURS FROM THE TIME OWNER ISSUES SUCH WRITTEN NOTICE OF NONCOMPLIANCE, OR WITHIN THE TIME OF ABATEMENT PERIOD SPECIFIED BY ANY GOVERNMENTAL AGENCY, WHICHEVER PERIOD IS SHORTER, CONTRACTOR SHALL BE IN MATERIAL DEFAULT OF THIS CONTRACT.
3. THE PROJECT DESIGN HAS BEEN BASED UPON FIELD SURVEYS AND SITE VISITS BY J. BROWN PROFESSIONAL GROUP.
4. CONTRACTOR SHALL FAMILIARIZE HIMSELF WITH THE SITE, INCLUDING ALL SURFACE AND SUBSURFACE CONDITIONS, LIMITS OF CONSTRUCTION, WORK REQUIRED AND ALL OTHER CONDITIONS THAT MAY EFFECT THE SUCCESSFUL COMPLETION OF THE PROJECT, PRIOR TO THE COMMENCEMENT OF WORK. IF CONTRACTOR DISCOVERS ANY ERRORS OR OMISSIONS IN THE PLANS OR SPECIFICATIONS, HE SHALL IMMEDIATELY NOTIFY OWNER OR OWNER'S AGENT.
5. CONTRACTOR SHALL OBTAIN ALL REQUIRED PERMITS NOT PROVIDED, GIVE ALL NOTICES REQUIRED BY, AND COMPLY WITH ALL APPLICABLE LAWS, ORDINANCES, RULES, STATUTES, REGULATIONS, AND PERMIT CONDITIONS BEARING ON THE EXECUTION OF PROJECT, AS DRAWN AND SPECIFIED. IF CONTRACTOR OBSERVES THAT THE DRAWINGS OR SPECIFICATION ARE IN VARIANCE WITH ANY APPLICABLE LAWS, ORDINANCES, RULES, STATUTES, REGULATIONS OR PERMIT CONDITIONS, HE SHALL TAKE ANY ACTIONS NECESSARY TO MITIGATE ANY POTENTIAL DAMAGE, AND PROMPTLY NOTIFY ENGINEER IN WRITING OF SUCH VARIANCE. ANY NECESSARY CHANGES TO THE DRAWING AND SPECIFICATIONS SHALL BE MADE IN ACCORDANCE WITH THE PROVISIONS OF THE AGREEMENT BETWEEN OWNER AND CONTRACTOR.
6. CONTRACTOR SHALL BE RESPONSIBLE TO OWNER AND ENGINEER FOR THE ACTS AND OMISSIONS OF THE CONTRACTOR'S EMPLOYEES, AND ALL SUBCONTRACTORS AND THEIR AGENTS AND EMPLOYEES, AND ANY OTHER PERSONS PERFORMING ANY WORK UNDER THIS CONTRACT BETWEEN OWNER AND CONTRACTOR, FOR THIS PROJECT.
7. CONTRACTOR SHALL BE RESPONSIBLE FOR MAKING ALL NECESSARY ARRANGEMENTS WITH ALL GOVERNMENTAL AGENCIES, DEPARTMENT OR BODIES, PUBLIC AND PRIVATE UTILITIES, CARRIERS OR SERVICE COMPANIES, AND CORPORATIONS OWNING OR CONTROLLING ANY ROADWAYS, RAILWAYS, WATER, SEWER, GAS, ELECTRICAL, TELEPHONE OR TELEGRAPH FACILITIES, SUCH AS PAVEMENT, TRACKS, PIPING, WIRES, CABLES, CONDUITS, POLES, GUYS OR OTHER SIMILAR FACILITIES, INCLUDING INCIDENTAL STRUCTURES CONNECTED TO SUCH SERVICES, THAT ARE ENCOUNTERED DURING THE PROJECT, IN ORDER THAT SUCH ITEMS MAY BE PROPERLY PROTECTED, SUPPORTED OR RELOCATED AS NEEDED.
8. UNLESS OTHERWISE SPECIFIED IN THESE GENERAL CONDITIONS, SPECIFICATIONS OR IN THE AGREEMENT BETWEEN OWNER AND CONTRACTOR, ALL CONSTRUCTION IS TO BE GOVERNED BY THE PLANS, SPECIFICATION AND APPLICABLE PERMITS, ALL APPLICABLE FEDERAL, STATE AND LOCAL LAWS, ORDINANCES, RULES, STATUTES, REGULATIONS, PERMIT CONDITIONS AND BUILDING AND SAFETY CODES BEARING ON THE EXECUTION OF THE PROJECT.
9. PRIOR TO PERFORMING ANY WORK WITHIN ANY PUBLIC OR UTILITY RIGHT-OF-WAY OR EASEMENT, CONTRACTOR SHALL OBTAIN AUTHORIZATION AND PERMITS FROM THE APPLICABLE JURISDICTION RESPONSIBLE FOR SUCH RIGHT-OF-WAY OR EASEMENT. ADDITIONALLY, CONTRACTOR SHALL NOTIFY SUNSHINE STATE ONE CALL AT 1 (800) 432-4770 AT LEAST 72 HOURS PRIOR TO DIGGING OR OTHERWISE DISTURBING UTILITIES.
10. CONTRACTOR SHALL PRESERVE AND PROTECT ALL PERMANENT REFERENCE MONUMENTS, CONTROL POINTS, BENCHMARKS AND PROPERTY CORNERS. IN THE EVENT ANY REFERENCE MONUMENTS, CONTROL POINTS, BENCHMARKS OR PROPERTY CORNERS ARE DISTURBED, CONTRACTOR SHALL EMPLOY A FLORIDA REGISTERED LAND SURVEYOR TO RESET OR REPLACE SUCH.
11. THE OWNER, OWNER'S AGENT AND INSPECTORS OF APPLICABLE GOVERNMENT JURISDICTIONS AND AGENCIES SHALL HAVE ACCESS TO THE PROJECT AT ALL TIMES. CONTRACTOR SHALL PROVIDE REASONABLE AND PROPER FACILITIES FOR SUCH ACCESS AND INSPECTION OF THE WORK.
12. CONTRACTOR SHALL COMPLY IN EVERY ASPECT WITH THE FEDERAL OCCUPATIONAL SAFETY AND HEALTH ACT OF 1970 (OSHA) AS AMENDED AND ALL RULES, STATUTES AND REGULATIONS NOW OR HEREAFTER IN EFFECT UNDER SAID ACT. THE CONTRACTOR FURTHER AGREES TO COMPLY WITH ANY OTHER APPLICABLE FEDERAL, STATE AND LOCAL LAWS, ORDINANCES, RULES, STATUTES, REGULATIONS OR PERMIT CONDITIONS PERTAINING TO JOB SAFETY AND HEALTH, INCLUDING, BUT NOT LIMITED TO CFR 1910 AND 1926.
13. CONTRACTOR SHALL COMPLY WITH ALL APPLICABLE BUILDING AND SAFETY CODES, FEDERAL, STATE, AND LOCAL LAWS, ORDINANCES, RULES, STATUTES, REGULATIONS OR PERMIT CONDITIONS, INCLUDING BUT NOT LIMITED TO, LAWFUL ORDERS OF ANY QUASI PUBLIC OR OTHER AUTHORITY HAVING JURISDICTION FOR THE SAFETY OF PERSONS OR PROPERTY OR FOR THE PROTECTION AGAINST INJURY, DAMAGE, OR LOSS TO PERSONNEL, EQUIPMENT OR MATERIALS, OR DESIGNED TO PROTECT THE ENVIRONMENT. CONTRACTOR SHALL ERECT AND MAINTAIN, AS REQUIRED BY EXISTING CONDITIONS AND PROGRESS OF THE WORK, ALL REASONABLE AND REQUIRED SAFEGUARDS FOR THE SAFETY AND PROTECTION OF ALL PERSONNEL, EQUIPMENT OR MATERIALS, INCLUDING BUT NOT LIMITED TO, POSTING OF DANGER SIGNS AND OTHER WARNING AGAINST HAZARDS, PROMULGATING SAFETY REGULATIONS AND NOTIFYING OWNERS AND USERS OF ADJACENT UTILITIES OF THE EXISTENCE OF HAZARDS AND SAFETY REGULATIONS.
14. CONTRACTOR SHALL BE RESPONSIBLE TO PROVIDE ALL REASONABLE AND PRUDENT PRECAUTIONS FOR THE SAFE AND SECURE PROTECTION OF ALL INCOMPLETE WORK, MATERIALS AND EQUIPMENT STORED ONSITE AND OFFSITE, AND ANY UNAUTHORIZED ACCESS TO SUCH.
15. CONTRACTOR SHALL, AT ALL TIMES, UTILIZE ALL NORMALLY ACCEPTED AND REASONABLY EXPECTED SAFETY PRACTICES AND COMPLY WITH ALL APPLICABLE FEDERAL, STATE, AND LOCAL LAWS, ORDINANCES, RULES, STATUTES, REGULATIONS OR PERMIT CONDITIONS, AND GUIDELINES AND RECOMMENDATIONS PERTAINING TO THE SAFE UTILIZATION OF ALL EQUIPMENT AND MATERIALS, AS PUBLISHED BY MANUFACTURER OR SUPPLIER.
16. PRIOR TO INITIATING ANY EXCAVATION (INCLUDING, BUT NOT LIMITED TO, TUNNELS, DITCHES, SWALES, STORMWATER PONDS, CANALS, OR ARTIFICIAL LAKES), CONTRACTOR SHALL REVIEW AND MAKE ARRANGEMENTS TO COMPLY IN EVERY RESPECT WITH THE PROVISIONS OF ALL APPLICABLE FEDERAL, STATE, AND LOCAL LAWS, ORDINANCES, RULES, STATUTES, REGULATIONS OR PERMIT CONDITIONS, (INCLUDING BUT NOT LIMITED TO CFR 1926 SUBPART P, OSHA DIRECTIVES CPL 2.69 AND 2.87 AND STATE OF FLORIDA DHR REQUIREMENTS) PERTAINING TO SAFE TRENCHING AND EXCAVATION. CONTRACTOR SHALL INSTALL ALL NECESSARY FENCES AND BARRIERS, AND TAKE ALL OTHER REASONABLE AND PRUDENT STEPS TO ENSURE THAT ACCESS TO EXCAVATIONS BY UNAUTHORIZED INDIVIDUALS IS PREVENTED.

GENERAL NOTES (CONT.)

17. CONTRACTOR SHALL TAKE ALL REASONABLE PRECAUTIONS FOR THE SAFETY OF, AND SHALL PROVIDE ALL REASONABLE AND REQUIRED PROTECTION TO PREVENT INJURY, DAMAGE OR LOSS TO:

A. ALL INDIVIDUALS INCLUDING CONTRACTOR'S EMPLOYEES, AND ALL SUBCONTRACTORS AND THEIR AGENTS AND EMPLOYEES, INSPECTORS AND ANY OTHER PERSONS PERFORMING ANY WORK UNDER A CONTRACT WITH THE CONTRACTOR;

B. ALL THE WORK, MATERIALS AND EQUIPMENT TO BE INCORPORATED INTO THE FINAL PRODUCT, WHETHER IN STORAGE ONSITE OR OFFSITE, UNDER THE CARE, CUSTODY OR CONTROL OF THE CONTRACTOR OR ANY OF THE SUBCONTRACTORS; AND

C. OTHER PROPERTY AT THE SITE OR ADJACENT TO THE SITE, INCLUDING BUT NOT LIMITED TO TREES, SHRUBS, LAWNS, WALKS, PAVEMENTS, ROADWAYS, STRUCTURES AND UTILITIES NOT DESIGNATED FOR REMOVAL OR DEMOLITION DURING THE COURSE OF THE PROJECT.

D. ALL DAMAGE OR LOSS TO ANY PROPERTY, UNTIL FINAL ACCEPTANCE OF THE WORK BY THE OWNER, CAUSED IN WHOLE OR IN PART BY THE CONTRACTOR, CONTRACTOR'S EMPLOYEES, ANY SUBCONTRACTORS OR THEIR AGENTS, EMPLOYEES OR OTHER PERSONS PERFORMING WORK UNDER A CONTRACT WITH THE CONTRACTOR FOR WHOSE ACTS ANY OF THEM MAY BE LIABLE, SHALL BE REMEDIED BY THE CONTRACTOR, EXCEPT FOR DAMAGE OR PROPERTY LOSS ATTRIBUTED SOLELY TO THE ACTS OR OMISSIONS OF THE OWNER OR THE ENGINEER, OR ANY SUBCONTRACTORS OR THEIR AGENTS, EMPLOYEES OR OTHER PERSONS PERFORMING WORK FOR THEM, OR FOR WHOSE ACTS ANY OF THEM MAY BE LIABLE, SHALL AND NOT PROPERLY ATTRIBUTABLE IN WHOLE OR IN PART TO THE FAULT OR NEGLIGENCE OF THE CONTRACTOR.
18. ALL INJURY, DAMAGE OR LOSSES TO ANY PERSONNEL, EQUIPMENT, MATERIALS OR PROPERTY, AS NOTED IN THIS PARAGRAPH 18, CAUSED IN WHOLE OR IN PART, THROUGH FAULT OR NEGLIGENCE BY CONTRACTOR, SUBCONTRACTORS, SUPPLIERS OR BY ANYONE FOR WHOSE ACTS ANY OF THEM MAY BE LIABLE, SHALL BE REMEDIED BY THE CONTRACTOR, EXCEPT FOR INJURY, DAMAGE OR LOSS PROPERLY ATTRIBUTABLE SOLELY TO THE ACTS, ERRORS OR OMISSIONS OF OWNER, ENGINEER OR ANYONE EMPLOYED BY THEM, OR FOR THOSE ACTS ANY OF THEM MAY BE LIABLE AND NOT PROPERLY ATTRIBUTABLE IN WHOLE OR IN PART TO THE FAULT OR NEGLIGENCE OF THE CONTRACTOR.
19. UNTIL THE FINAL ACCEPTANCE OF THE PROJECT BY OWNER, CONTRACTOR SHALL HAVE THE COMPLETE CHARGE AND CARE OF, AND SHALL BEAR ALL RISKS AND EXPENSES FOR ANY INJURY, DAMAGE OR LOSS, OR TO ANY PORTION OF THE WORK, ALL MATERIALS STORED ONSITE OR OFFSITE BY THE ACTION OF THE ELEMENTS, OR FROM ANY OTHER CAUSE WHETHER ARISING FROM THE EXECUTION OR NON-EXECUTION OF THE WORK. CONTRACTOR SHALL BEAR ALL EXPENSES FOR ANY REPAIRS, REBUILDING OR RESTORATION, AND MAKE GOOD ALL INJURIES, DAMAGES OR LOSSES TO ANY PORTION OF THE WORK BEFORE FINAL ACCEPTANCE OF THE PROJECT BY OWNER.
20. CONTRACTOR SHALL NOT LOAD, CAUSE OR PERMIT ANY PART OF THE WORK TO BE LOADED SO AS TO ENDANGER SAFETY.
21. THOSE PARTS OF THE WORK IN PLACE, WHICH ARE SUBJECT TO DAMAGE, BECAUSE OF ACTIVITIES OR OPERATIONS BEING CARRIED OUT ADJACENT TO, SHALL BE COVERED, BOARDED UP OR SUBSTANTIALLY ENCLOSED WITH ADEQUATE PROTECTION BY CONTRACTOR AT HIS EXPENSE.
22. PERMANENT OPENINGS USED AS THOROUGHFARES FOR THE INTRODUCTION OF WORK, PERSONNEL, EQUIPMENT AND/OR MATERIALS TO STRUCTURES SHALL HAVE HEADS, JAMBS AND SILLS WELL BLOCKED AND BOARDED BY THE CONTRACTOR. OWNER RETAINS THE AUTHORITY, BUT ASSUMES NO DUTY TO ESTABLISH STANDARDS OF PROTECTION, AND TO REVIEW THE EFFICIENCY OF PROTECTIVE MEASURES TAKEN BY CONTRACTOR.
23. ADEQUATE TRAFFIC CONTROL, BARRICADES AND FLAGMEN SERVICES SHALL BE FURNISHED AND MAINTAINED BY CONTRACTOR AT ALL POINTS WHERE CONVEYING EQUIPMENT ENGAGED ON THE WORK REGULARLY ENTER ONTO, EXITS FROM OR CROSSES TRAFFIC CARRYING ROADS.
24. CONTRACTOR SHALL PROTECT AND KEEP OWNER (INCLUDING THEIR AGENTS AND EMPLOYEES) FREE AND HARMLESS FROM ANY AND ALL LIABILITY, PUBLIC OR PRIVATE, PENALTIES, CONTRACTUAL OR OTHERWISE, LOSSES, DAMAGES, COST, ATTORNEY'S FEES, EXPENSES, CAUSE OF ACTION, CLAIMS OR OTHER JUDGMENTS RESULTING FROM VIOLATIONS UNDER OSHA OR ANY RULES, STATUTES OR REGULATIONS PROMULGATED THERE UNDER, OR ANY FEDERAL, STATE OR LOCAL LAWS OR REGULATIONS PERTAINING TO JOB SAFETY AND HEALTH ARISING OUT OF, OR IN ANY WAY CONNECTED WITH THE PERFORMANCE OF THE WORK OR WORK TO BE PERFORMED ON THIS PROJECT. CONTRACTOR SHALL INDEMNIFY OWNER (INCLUDING THEIR AGENTS AND EMPLOYEES) FROM ANY SUCH CLAIMS, PENALTIES, SUITS OR ACTIONS, PUBLIC OR PRIVATE, ADMINISTRATIVE OR JUDICIAL, INCLUDING BUT NOT LIMITED TO ATTORNEY'S FEES PAID OR INCURRED BY, OR ON BEHALF OF OWNER, JOINTLY OR SEVERALLY, AND/OR THEIR AGENT AND EMPLOYEES. CONTRACTOR FURTHER AGREES IN THE EVENT OF A CLAIMED VIOLATION OF ANY FEDERAL, STATE OR LOCAL SAFETY AND HEALTH LAW OR REGULATION ARISING OUT OF, OR IN ANY WAY CONNECTED WITH THE PERFORMANCE OF THE WORK, OR WORK TO BE PERFORMED ON THIS PROJECT, OWNER MAY IMMEDIATELY TAKE ALL ACTIONS DEEMED NECESSARY TO REMEDY THE CLAIMED VIOLATIONS. ANY AND ALL COST OR EXPENSES PAID OR INCURRED BY OWNER IN TAKING SUCH ACTION SHALL BE BORNE SOLELY BY CONTRACTOR, AND CONTRACTOR AGREES TO PROTECT, HOLD HARMLESS AND INDEMNIFY OWNER AGAINST ANY AND ALL SUCH COST OR EXPENSES.
25. ALL WORK PERFORMED UNDER THIS CONTRACT, AND ALL EQUIPMENT, APPLIANCES, TOOLS AND LIKE ITEMS USED IN THE PERFORMANCE OF THE WORK SHALL CONFORM TO ALL APPLICABLE BUILDING AND SAFETY CODES, AND REGULATIONS OF ANY PUBLIC OR OTHER AUTHORITY HAVING JURISDICTION. IN THE EVENT OF CONFLICTING REQUIREMENTS, THE MORE STRINGENT INTERPRETATION OR REGULATION SHALL APPLY.
26. "HAZARDOUS MATERIALS" MEANS ANY SUBSTANCE WHICH:

A. THE PRESENCE OF REQUIRES INVESTIGATION OR REMEDIATION UNDER ANY PRESENT FEDERAL, STATE, AND LOCAL LAWS, ORDINANCES, RULES, STATUTES, REGULATIONS OR PERMIT CONDITIONS, OR

B. IS OR BECOMES DEFINED AS A "HAZARDOUS WASTE", "HAZARDOUS SUBSTANCE", POLLUTANT OR CONTAMINATE UNDER ANY PRESENT FEDERAL, STATE, AND LOCAL LAWS, ORDINANCES, RULES, STATUTES, REGULATIONS OR PERMIT CONDITIONS OR AMENDMENTS, INCLUDING BUT NOT LIMITED TO, THE 1980 COMPREHENSIVE ENVIRONMENTAL RESPONSE COMPENSATION AND LIABILITY ACT (CERCLA) AND/OR THE 1976 RESOURCE CONSERVATION AND RECOVERY ACT (RCRA), OR

C. IS TOXIC, EXPLOSIVE, CORROSIVE, FLAMMABLE, INFECTIOUS, RADIOACTIVE, CARCINOGENIC, MUTAGENIC OR OTHERWISE HAZARDOUS AND IS REGULATED BY ANY GOVERNMENTAL AUTHORITY, AGENCY, DEPARTMENT, COMMISSION, BOARD OR INSTRUMENTALITY OF THE UNITED STATES, THE STATE(S) IN WHICH THE PROJECT IS LOCATED OR ANY POLITICAL SUBDIVISION THEREOF, OR

D. THE PRESENCE OF ON THE PREMISES CAUSES OR THREATENS TO CAUSE A NUISANCE UPON THE PREMISES OR TO ADJACENT PROPERTIES OR POSES OR THREATENS TO POSE A HAZARD TO THE HEALTH OR SAFETY OF PERSONS ON OR ABOUT THE PREMISES, OR



E. THE PRESENCE OF ON THE PREMISES CAUSES OR THREATENS TO CAUSE A NUISANCE UPON THE PREMISES OR TO ADJACENT PROPERTIES OR POSES OR THREATENS TO POSE A HAZARD TO THE ENVIRONMENT, OR

F. CONTAINS GASOLINE, DIESEL FUEL OR OTHER PETROLEUM HYDROCARBONS, OR

G. CONTAIN POLYCHLORINATED BIPHENYLS (PCB'S), ASBESTOS, MERCURY, LEAD OR UREA FORMALDEHYDE FOAM INSULATION.
27. ALL DISTRUBED AREAS NOT PAVED SHALL BE SODDED. SOD SPECIES SHALL BE APPROVED BY FDEP, AND SHALL NOT CONTAIN MESH BACKING.

SHEET NO.		12087 ICHETUCKNEE SPRINGS STATE PARK SOUTHWEST U.S. 27, FORT WHITE, FL 32038 SHEET TITLE		PROFESSIONAL REGISTRATION BENJAMIN R. LENNON, P.E. FLORIDA ENGINEER #78674		DESIGNER : BRL DRAWN BY: RAJ REVIEWED BY: RRC Consultant :		ISSUE DATE: 6/5/2023 COMP. FILE NO.: 14-0210.038 STATE PROJECT NO.: 613633C		SYMBOL A B		REVISION		DATE		REVISION		DATE	
PROJECT TITLE ICHETUCKNEE SPRINGS STATE PARK REPLACE RESTROOM		GENERAL NOTES		Department of Environmental Protection Office of Operations Bureau of Design and Construction 3800 Commonwealth Blvd., Tallahassee, FL 32399 (850) 425-2300 DRMP DESIGNER-REGISTERED PROFESSIONAL ENGINEER Certified Professional Engineer #2646 Tallahassee, Florida 32317 Phone: 850.922.9600 WWW.DRMP.COM															

 P:\Projects\14-0210.038 (TA38)_Ichetucknee_Restroom\CADD\14-0210.038 (TA38)_VICINITY MAP.dwg Plotted: Aug 14, 2023 - 11:12am by Blennon

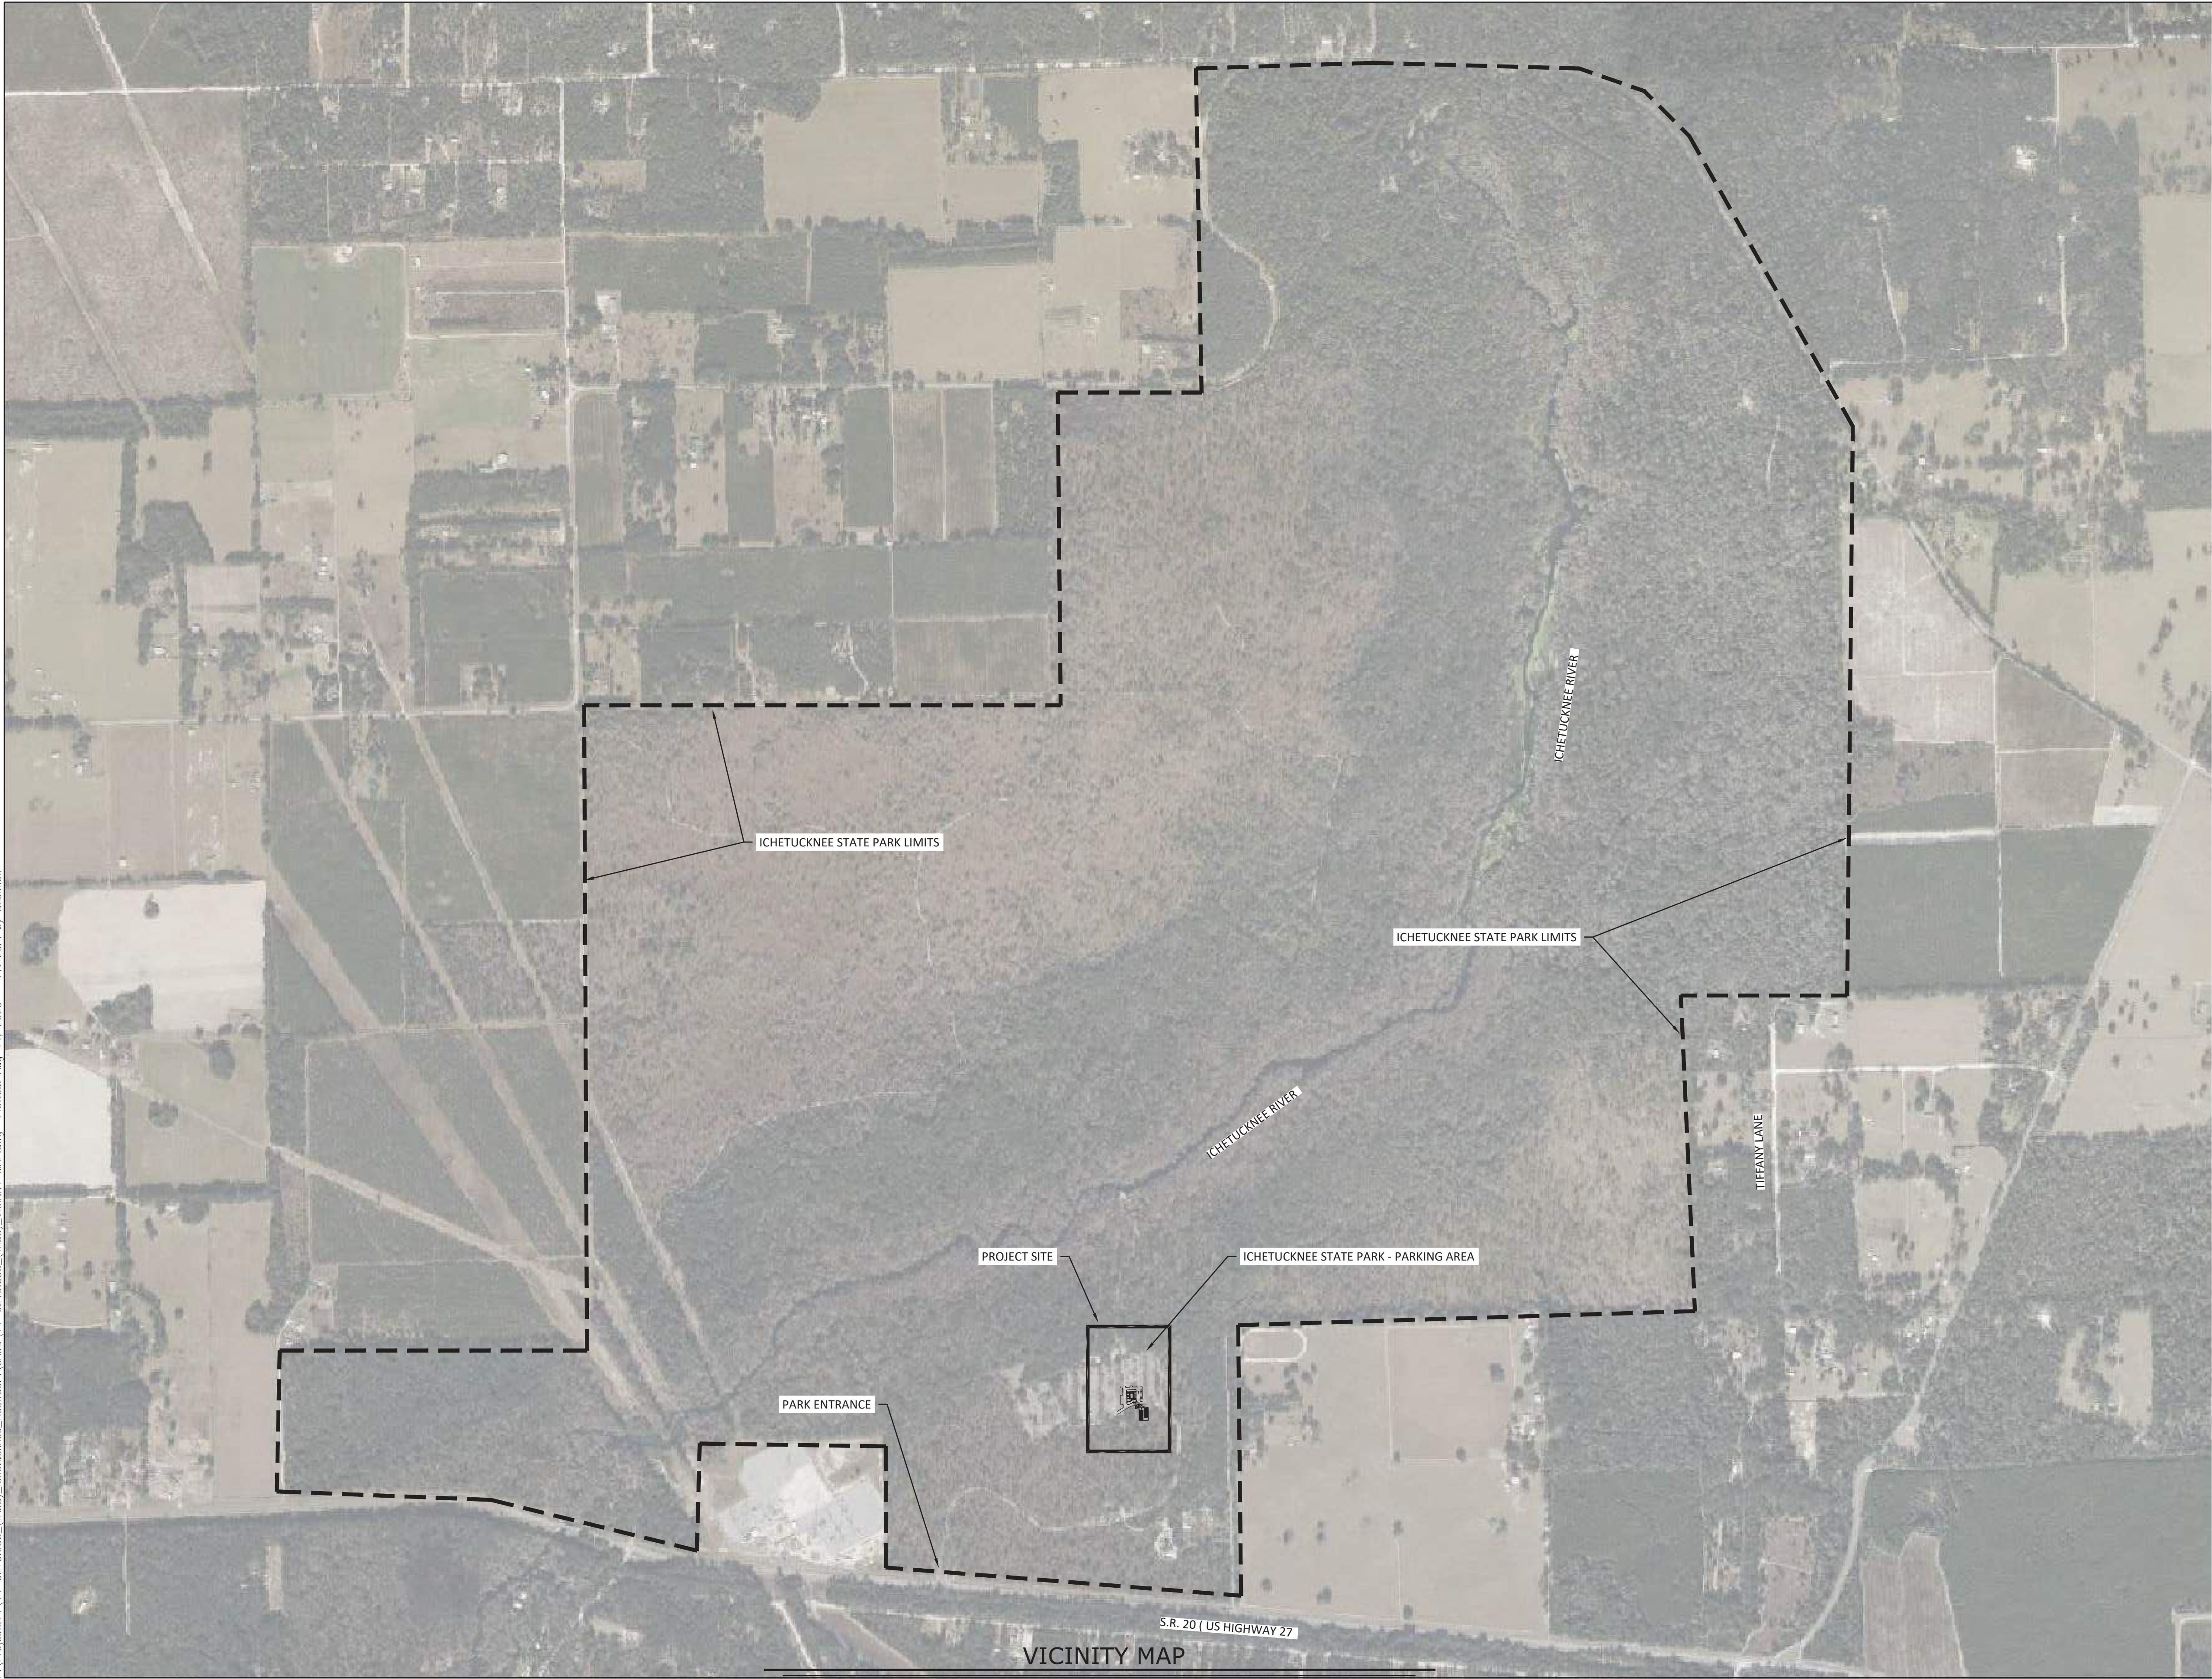

SHEET NO.		ICHETUCKNEE SPRINGS STATE PARK 12087 SOUTHWEST U.S. 27, FORT WHITE, FL 32038		PROFESSIONAL REGISTRATION BENJAMIN R. LENNON, P.E. FLORIDA ENGINEER #78674		DESIGNER : BRL	ISSUE DATE: 6/5/2023	SYMBOL	REVISION	DATE
SHEET TITLE		VICINITY MAP				DRAWN BY: RAJ	COMP. FILE No: 14-0210.038	A		
PROJECT TITLE		ICHETUCKNEE SPRINGS STATE PARK REPLACE RESTROOM				REVIEWED BY: RRC	STATE PROJECT No: 61363C	B		
						Consultant :				
						 DRMP DESIGNERS & ARCHITECTS PLANNERS & ENGINEERS Certified 1825 Summit Lake Drive Tallahassee, Florida 32317 Phone: 850.822.9600 WWW.DRMP.COM		Department of Environmental Protection Office of Operations <i>Bureau of Design and Construction</i> 3800 Commonwealth Blvd., Tallahassee, FL 32399 (850) 425-2300		

1. CONTRACTOR IS RESPONSIBLE FOR OBTAINING A NPDES PERMIT OR EXEMPTION PRIOR TO CONSTRUCTION.
2. EROSION CONTROL MEASURES ARE TO BE ACCOMPLISHED PRIOR TO ANY CONSTRUCTION ON THE SITE AND MAINTAINED UNTIL PERMANENT GROUND COVER IS ESTABLISHED.
3. ADDITIONAL EROSION CONTROL MEASURES WILL BE EMPLOYED WHERE DETERMINED NECESSARY BY ACTUAL SITE CONDITIONS.
4. ALL DEVICES ARE TO BE MAINTAINED AND REPAIRED ON A REGULAR BASIS.
5. EXCESS SEDIMENT TO BE REMOVED WHEN SILT REACHES ONE-HALF (1/2) THE HEIGHT OF THE FENCE.
6. TEMPORARY GRASSING IS NOT TO BE LESS THAN TWO (2) DAYS AFTER COMPLETION OF ANY GRADING ACTIVITIES.
7. SILT FENCE MUST MEET THE REQUIREMENTS OF FDOT, STANDARD SPECIFICATIONS, LATEST EDITION.
8. PERMANENT VEGETATION SHALL BE INSTALLED AS SOON AS PRACTICAL FOLLOWING FINAL GRADING.
9. NOTIFY OWNER'S REPRESENTATIVE 48 HOURS PRIOR TO CONSTRUCTION.
10. EROSION CONTROL MEASURES WILL BE INSPECTED AT LEAST WEEKLY AND AFTER EACH RAIN, AND REPAIRED BY THE GENERAL CONTRACTOR AS NEEDED.
11. CONTRACTOR TO COMPLETELY SECURE FROM EROSION ANY STOCK PILE OF EARTHEN MATERIALS. THE CONTRACTOR SHALL DETERMINE THE LOCATION OF ANY MATERIAL STOCKPILE LOCATIONS PRIOR TO COMMENCING WORK. THE LOCATIONS WILL BE CONFIRMED WITH THE DESIGN ENGINEER AND CONTRACTING OFFICE. AND THE ESPC PLANS WILL BE "REDLINED" WITH APPROPRIATE BMP'S TO REFLECT THE LOCATIONS.
12. EROSION AND SEDIMENTATION CONTROL MEASURES AND PRACTICES SHALL BE MAINTAINED AT ALL TIMES. ADDITIONAL EROSION AND SEDIMENTATION CONTROL MEASURES AND PRACTICES SHALL BE INSTALLED IF DEEMED NECESSARY BY ON-SITE INSPECTION.
13. ALL DESIGN WILL CONFORM TO AND ALL WORK WILL BE PERFORMED IN ACCORDANCE WITH THE STANDARDS AND SPECIFICATIONS OF FDOT.
14. ADDITIONAL EROSION CONTROL DEVICES SHALL BE INSTALLED AS REQUIRED BY THE PROJECT ENGINEER, COUNTY REPRESENTATIVE OR AS CONDITIONS MAY DICTATE.
15. MAXIMUM CUT OR FILL SLOPES IS 3H:1V.

1. THE CONTRACTOR SHALL CONTROL ACCESS TO THE PROJECT SITE. TEMPORARY 6-FT HIGH(MIN.) CHAINLINK FENCE WITH SCREENING IS REQUIRED AROUND THE ENTIRE PERIMETER OF THE WORK ZONE TO PROHIBIT THE PUBLIC FROM ENTERING. COORDINATE ACCESS WITH PARK STAFF. OTHER PARTS OF THE PARK WILL BE IN-USE DURING CONSTRUCTION. ALL SECURITY AND ACCESS MANAGEMENT IS INCIDENTAL TO THE PROJECT - NO SEPARATE PAYMENT.
2. STAGING AND STORAGE SHALL BE COORDINATED WITH PARK STAFF.

1. CONTRACTOR IS RESPONSIBLE FOR ALL VEHICULAR AND PEDESTRIAN MAINTENANCE OF TRAFFIC ADJACENT TO THE PROJECT AREA. THIS MAY INCLUDE BUT NOT LIMITED TO SIGNS, BARRICADES, AND FLAGGERS. SIGNAGE AND PROCEDURES SHALL BE IN ACCORDANCE TO FDOT STANDARD PLANS 102-600.
2. COORDINATE ALL LANE CLOSURES WITH FDEP


1. CALL SUNSHINE 811 BEFORE DIGGING.
2. ALL EXISTING FACILITIES, CONCRETE, STRUCTURES, AND VEGETATION SHOWN TO REMAIN SHALL BE PROTECTED. CONTRACTOR IS RESPONSIBLE FOR REPLACING ANY DAMAGED ITEMS TO EQUAL OR BETTER CONDITION.

 BENCHMARK
 ○ 9 SYC TREE-SIZE(INCHES) AND SPECIES
 × 132.2 SPOT ELEVATION - SOFT SURFACE
 × 132.21 SPOT ELEVATION - HARD SURFACE
 - - - 150 - - - CONTOUR LINES

EP = EDGE OF PAVEMENT
BC = BACK OF CURB
JBPRO = JBROWN PROFESSIONAL GROUP
LB = LICENSED BUSINESS
LS = LICENSED SURVEYOR
NAD83(2011) = NORTH AMERICAN DATUM OF 1983, 2011 ADJUSTMENT
NAVD88 = NORTH AMERICAN VERTICAL DATUM OF 1988


TREES:

CH = CHERRY LAUREL
LA = LAUREL OAK
MULTI = MULTIPLE TRUNK
PI = PINE
PO = POST OAK
SY = SYCAMORE
TO = TURKEY OAK
TWIN = TWIN TRUNK
WO = WATER OAK

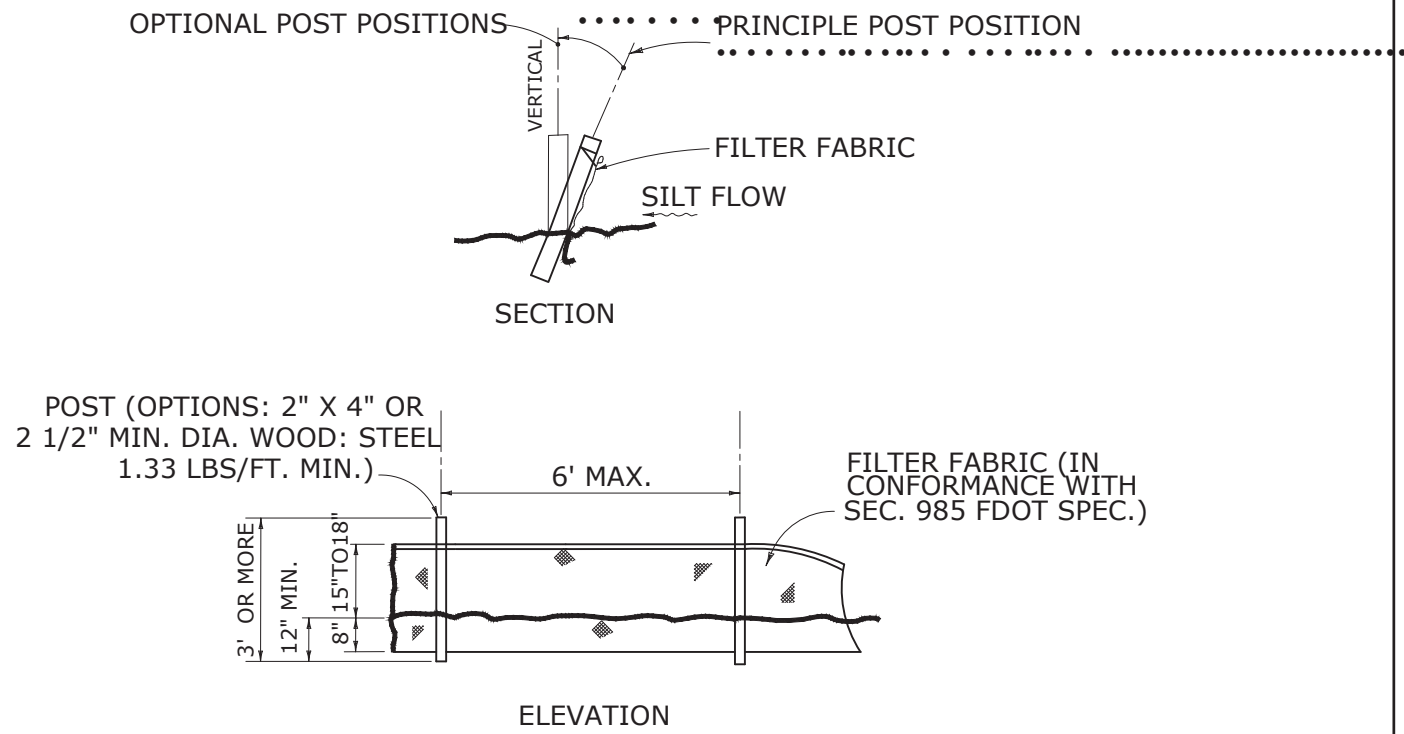


NOTE: SILT FENCE TO BE PAID FOR UNDER THE CONTRACT UNIT PRICE FOR STAKED SILT FENCE (LF).


N.T.S.

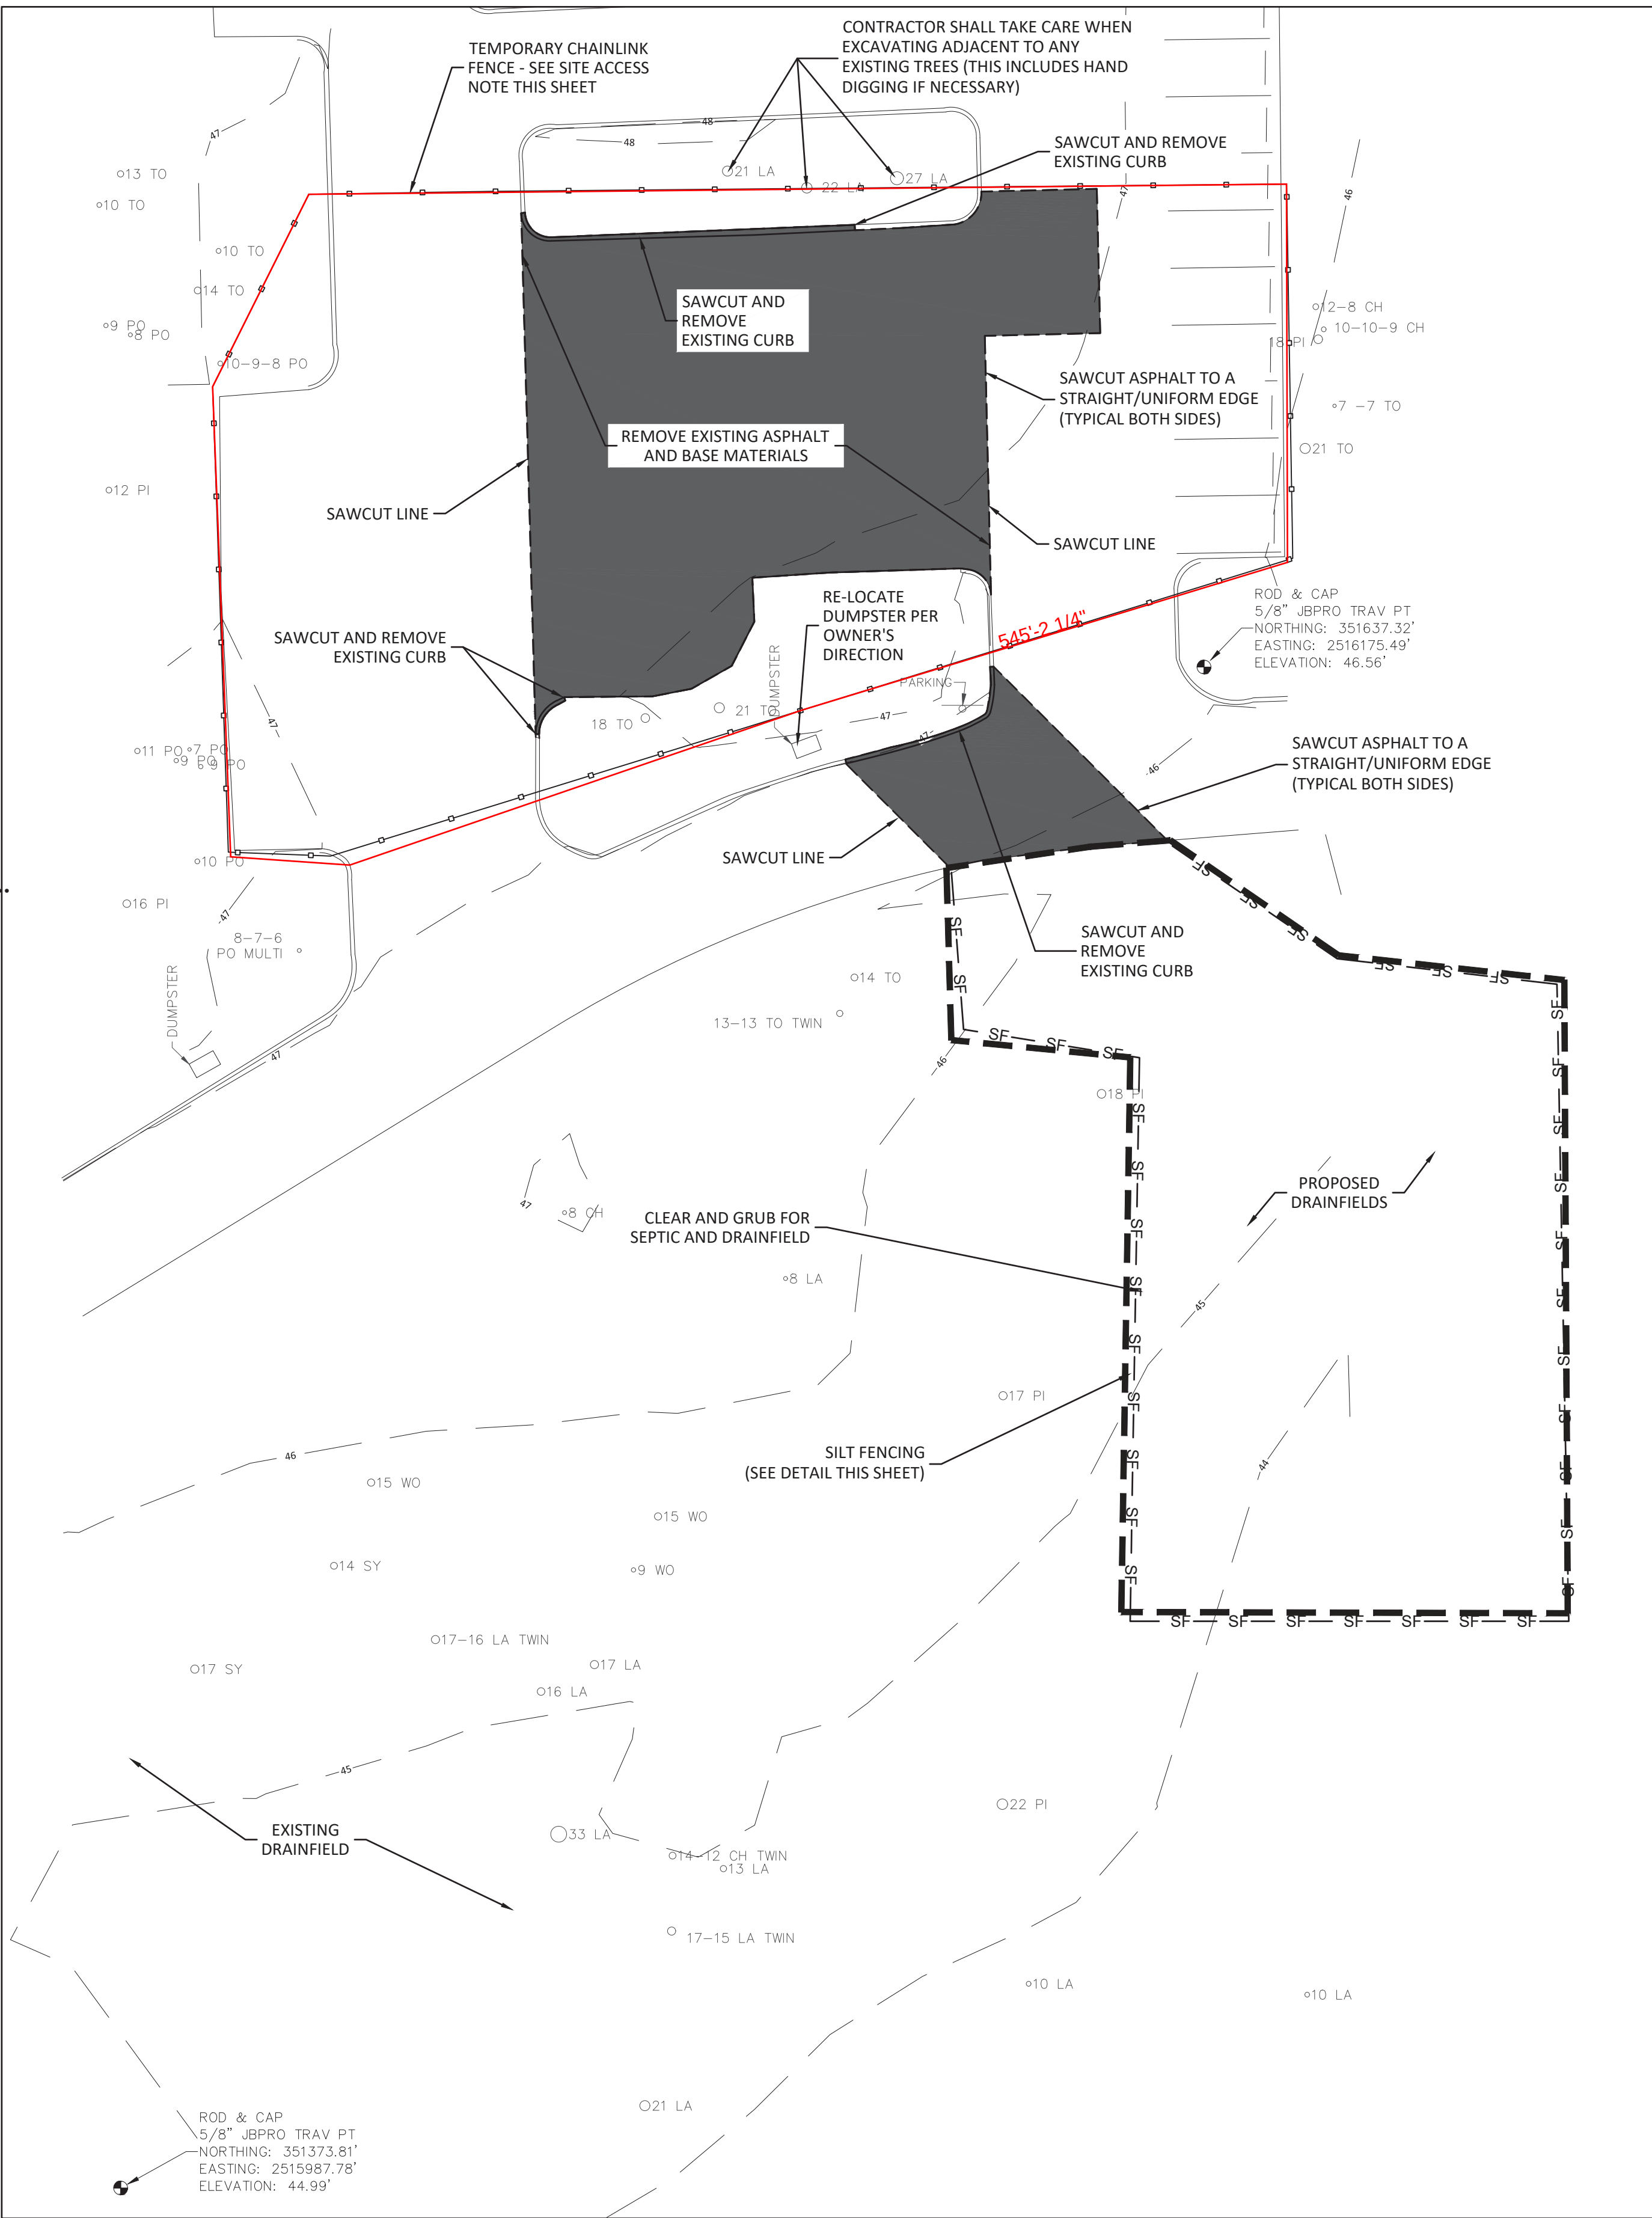


SCALE: 1" = 20'

 SHEET NO.	C100	SHEET TITLE ICHTUCKNEE SPRINGS STATE PARK 12087 SOUTHWEST U.S. 27, FORT WHITE, FL 32038 DEMOLITION AND EROSION CONTROL PLAN	PROFESSIONAL REGISTRATION BENJAMIN R. LENNON, P.E. FLORIDA ENGINEER #78674	DESIGNER : BRL DRAWN BY: RAJ								ISSUE DATE: 6/5/2023 COMP. FILE NO.: 14-0210.038		SYMBOL Ⓐ		REVISION		DATE	
				REVIEWED BY: RRC								STATE PROJECT NO.: 61363C		SYMBOL Ⓑ					
				Consultant : DRMP ENGINEERS • SURVEYORS • PLANNERS • DESIGNERS Certified Professional Engineer No. 2648 1826 Summit Lake Drive Tallahassee, Florida 32317 Phone: 850.462.9600 WWW.DRMP.COM								Department of Environmental Protection Office of Operations Bureau of Design and Construction 3800 Commonwealth Blvd., Tallahassee, FL 32399 (850) 425-2300							

P:\Projects\14-0210.038 (TA38)_Ichetucknee_Restroom\CADD\14-0210.038 (TA38)_SITE PLAN.dwg Plotted: Aug 14, 2023 - 11:13am by Blennon

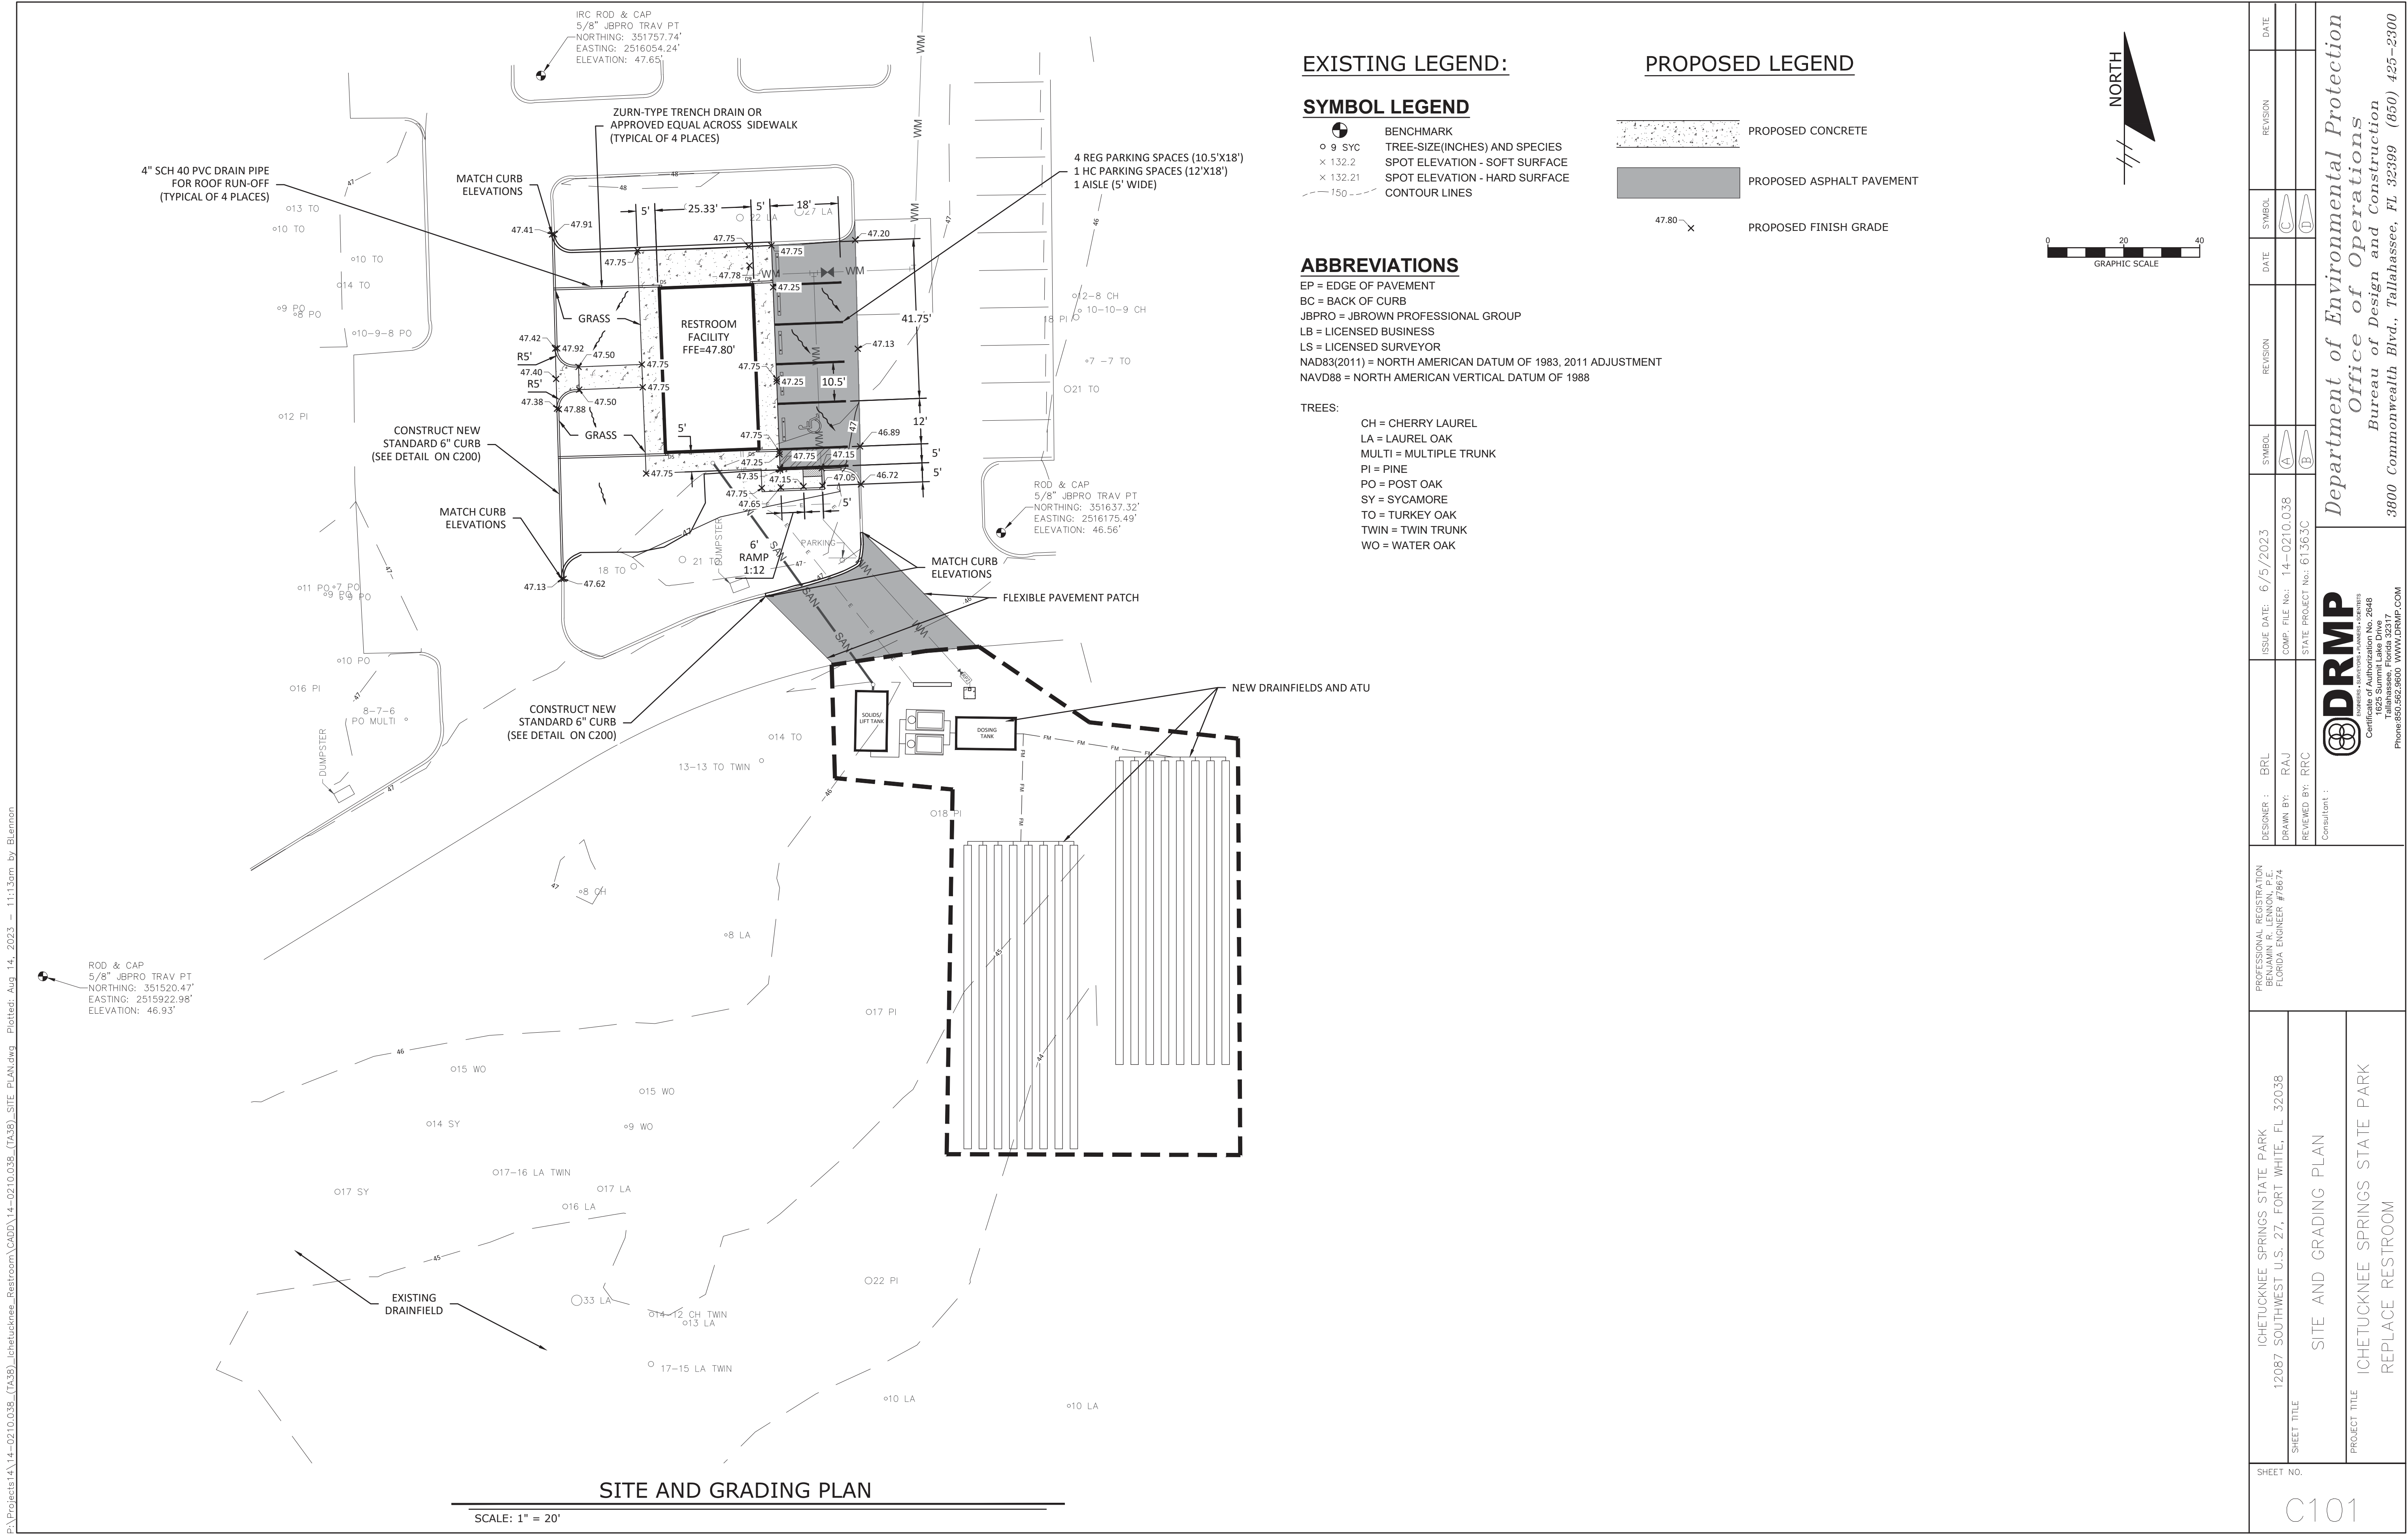


C101	SHEET NO.	SHEET TITLE	PROFESSIONAL REGISTRATION BENJAMIN R. LENNON, P.E. FLORIDA ENGINEER #75674	DESIGNER : BRL DRAWN BY: RAJ	ISSUE DATE: 6/5/2023 COMP. FILE NO.: 14-0210.038	SYMBOL 	REVISION	DATE	SYMBOL 	REVISION	DATE	SYMBOL
------	-----------	-------------	--	---------------------------------	---	---	----------	------	---	----------	------	--	----------	------	--	----------	------	--	----------	------	--	----------	------	--	----------	------	--	----------	------	--	----------	------	--	----------	------	--	----------	------	--	----------	------	--	----------	------	--	----------	------	--	----------	------	--	----------	------	--	----------	------	------------

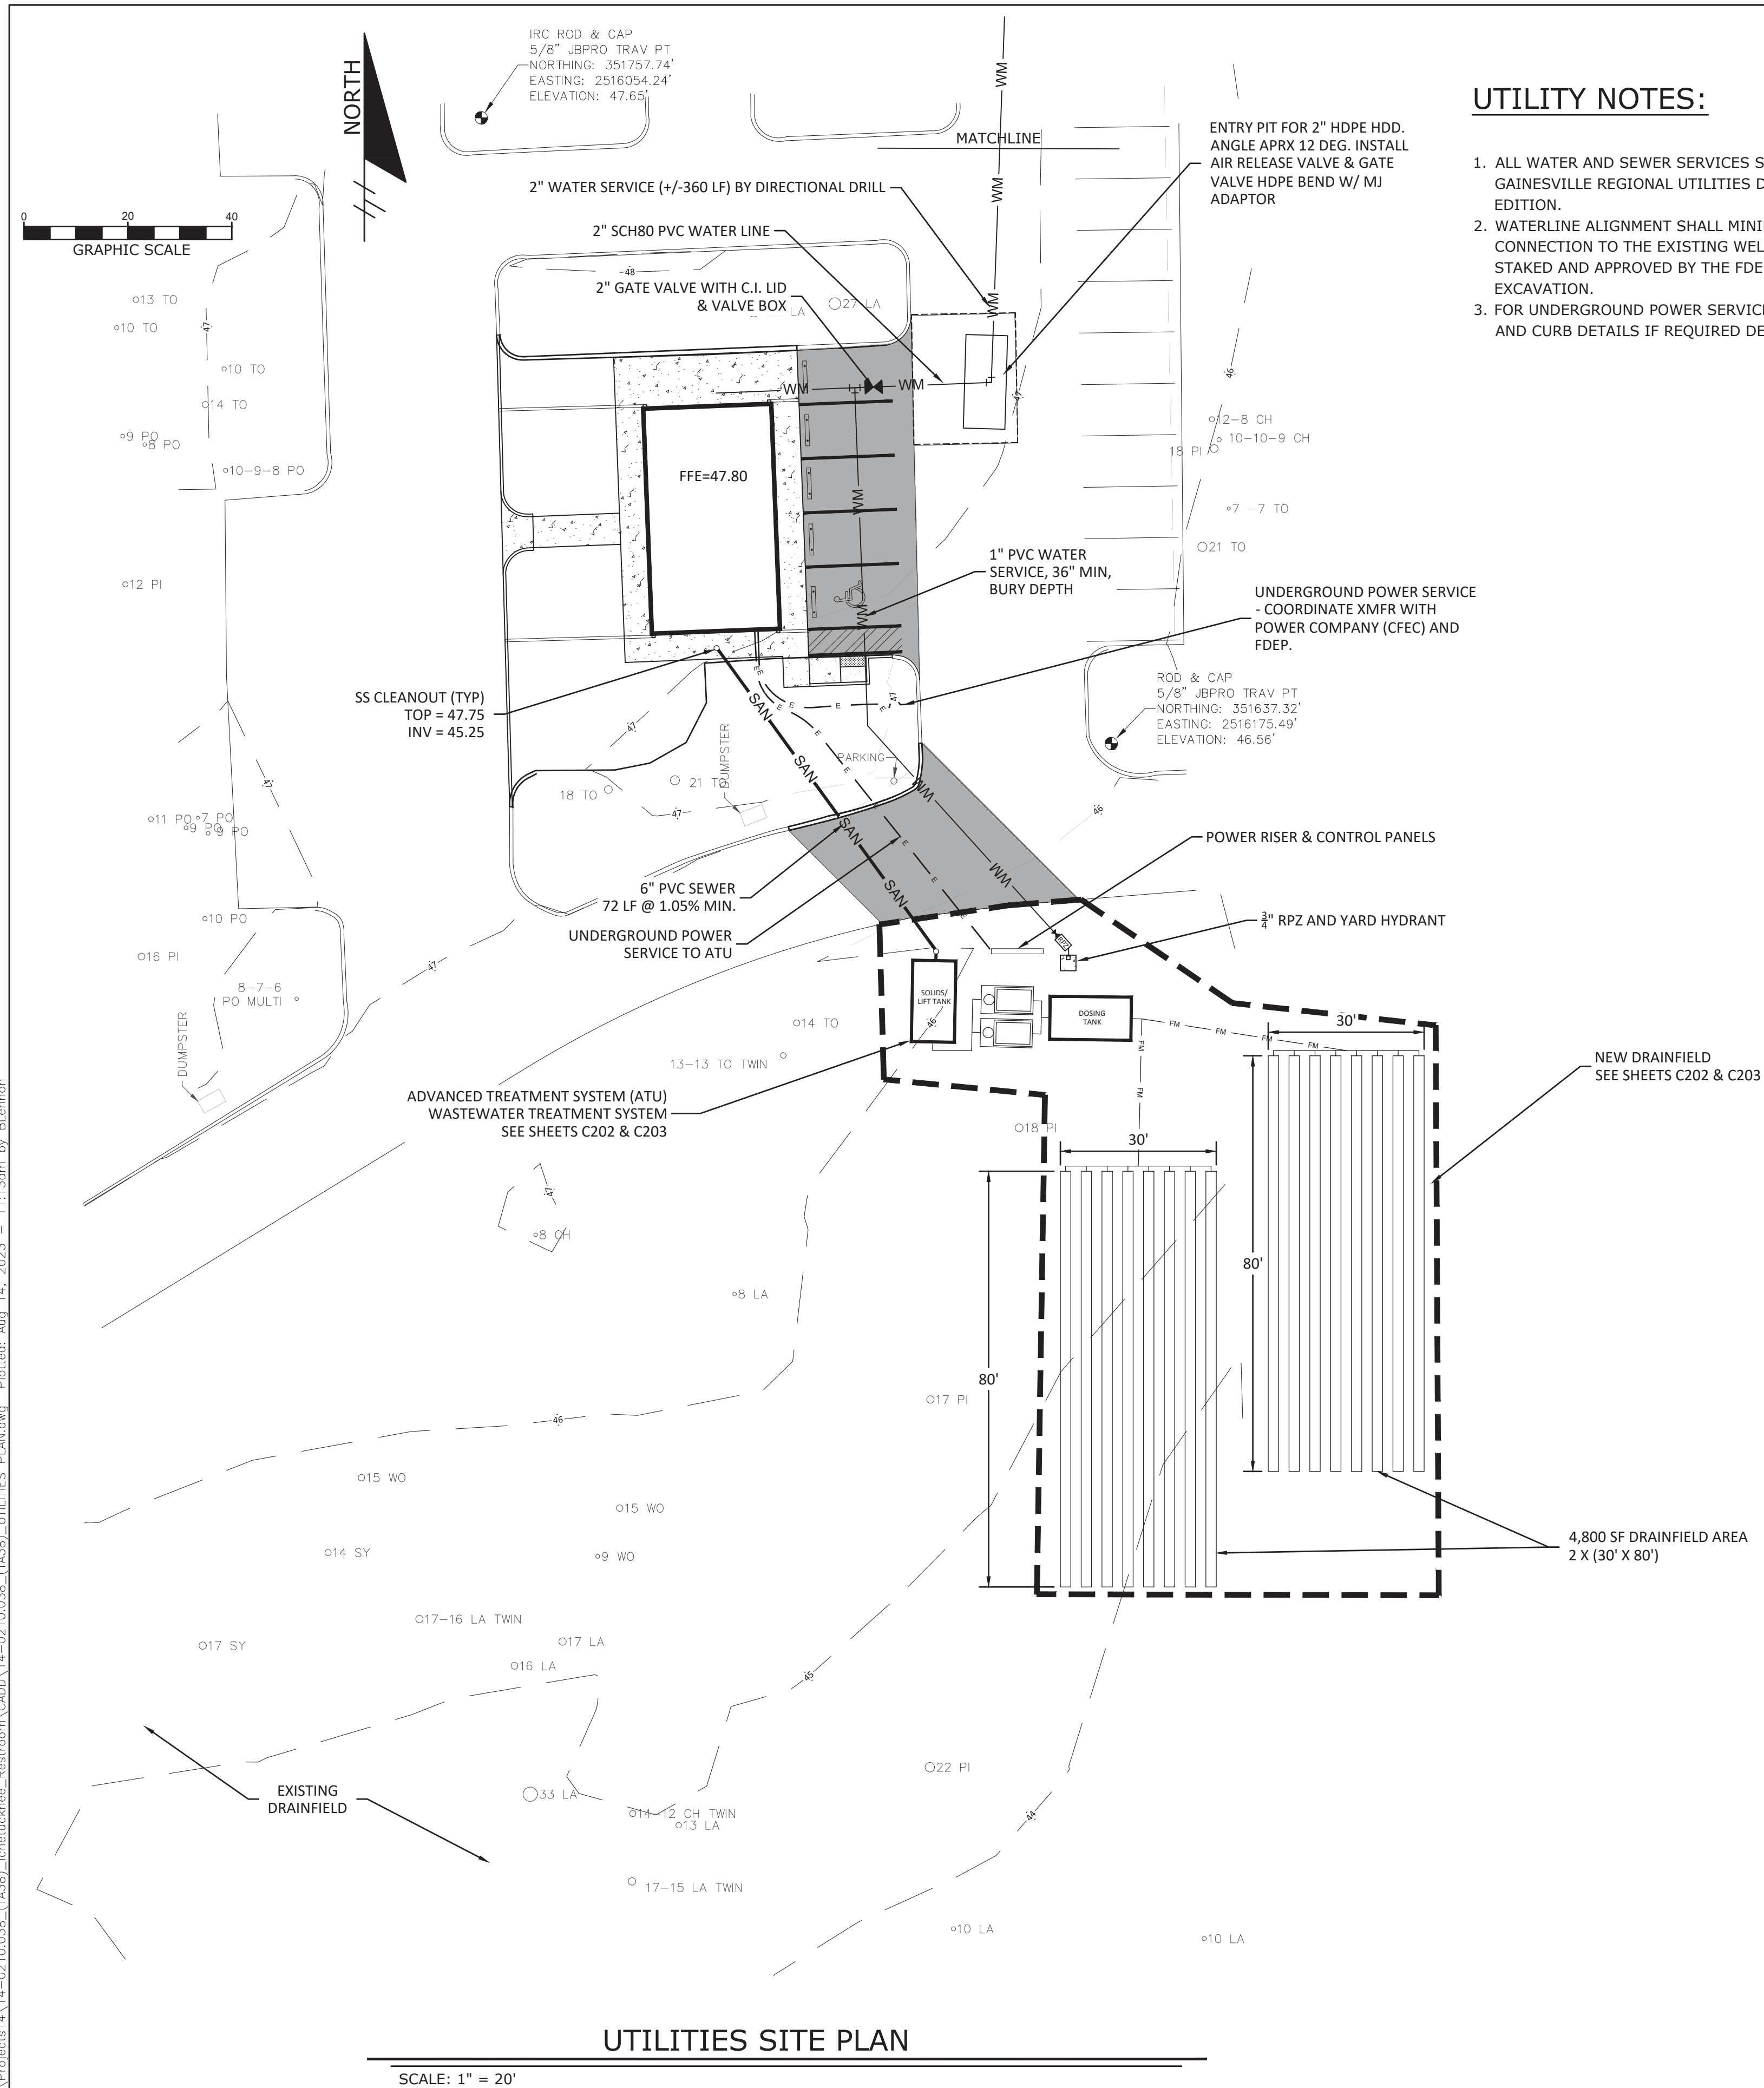

1. ALL WATER AND SEWER SERVICES SHALL BE CONSTRUCTED PER GAINESVILLE REGIONAL UTILITIES DESIGN STANDARDS, LATEST EDITION.
2. WATERLINE ALIGNMENT SHALL MINIMIZE TREE IMPACTS NEAR THE CONNECTION TO THE EXISTING WELL. ALIGNMENT SHALL BE STAKED AND APPROVED BY THE FDEP PROJECT MANAGER PRIOR TO EXCAVATION.
3. FOR UNDERGROUND POWER SERVICE, SEE OPEN CUT REPAIR DETAIL AND CURB DETAILS IF REQUIRED DEPENDING ON XMFR LOCATION.


SCALE: 1" = 20'

SHEET NO.	ICHTUCKNEE SPRINGS STATE PARK 12087 SOUTHWEST U.S. 27, FORT WHITE, FL 32038		PROFESSIONAL REGISTRATION STATE OF FLORIDA FLORIDA ENGINEER #78674	DESIGNER : BRL	ISSUE DATE: 6/5/2023	SYMBOL	REVISION	DATE
	SHEET TITLE UTILITY PLAN			DRAWN BY: RAJ	COMP. FILE No.: 14-0210.038	A		
C102	PROJECT TITLE ICHTUCKNEE SPRINGS STATE PARK REPLACE RESTROOM		CONSULTANT : DRMP ENGINEERS & ARCHITECTS, PLANNERS & DESIGNERS Certificate of Authorization No. 2848 8550 South U.S. Highway 27 Tallahassee, Florida 32317 Phone: 850.582.8600 WWW.DRMP.COM	REVIEWED BY: RRC	STATE PROJECT No.: 61363C	B		
				Department of Environmental Protection Office of Operations Bureau of Design and Construction 3800 Commonwealth Blvd., Tallahassee, FL 32399 (850) 425-2300				

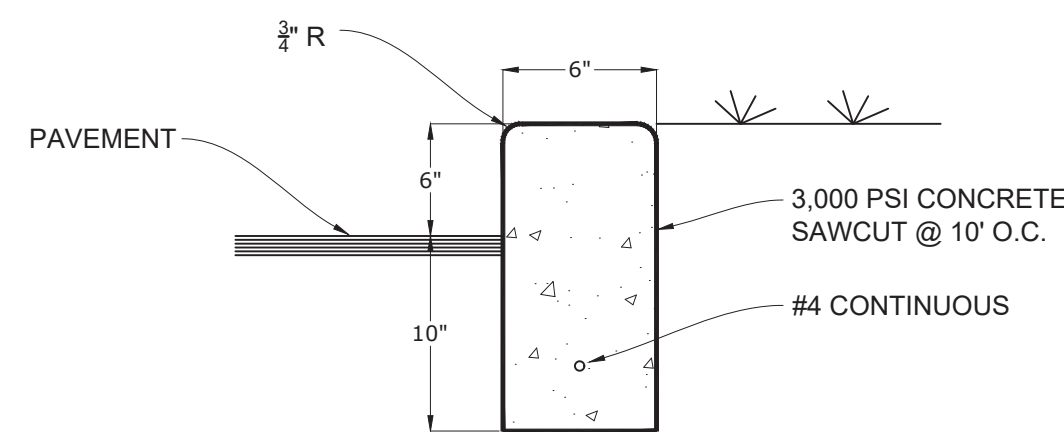


6" STANDARD CURB

N.T.S.

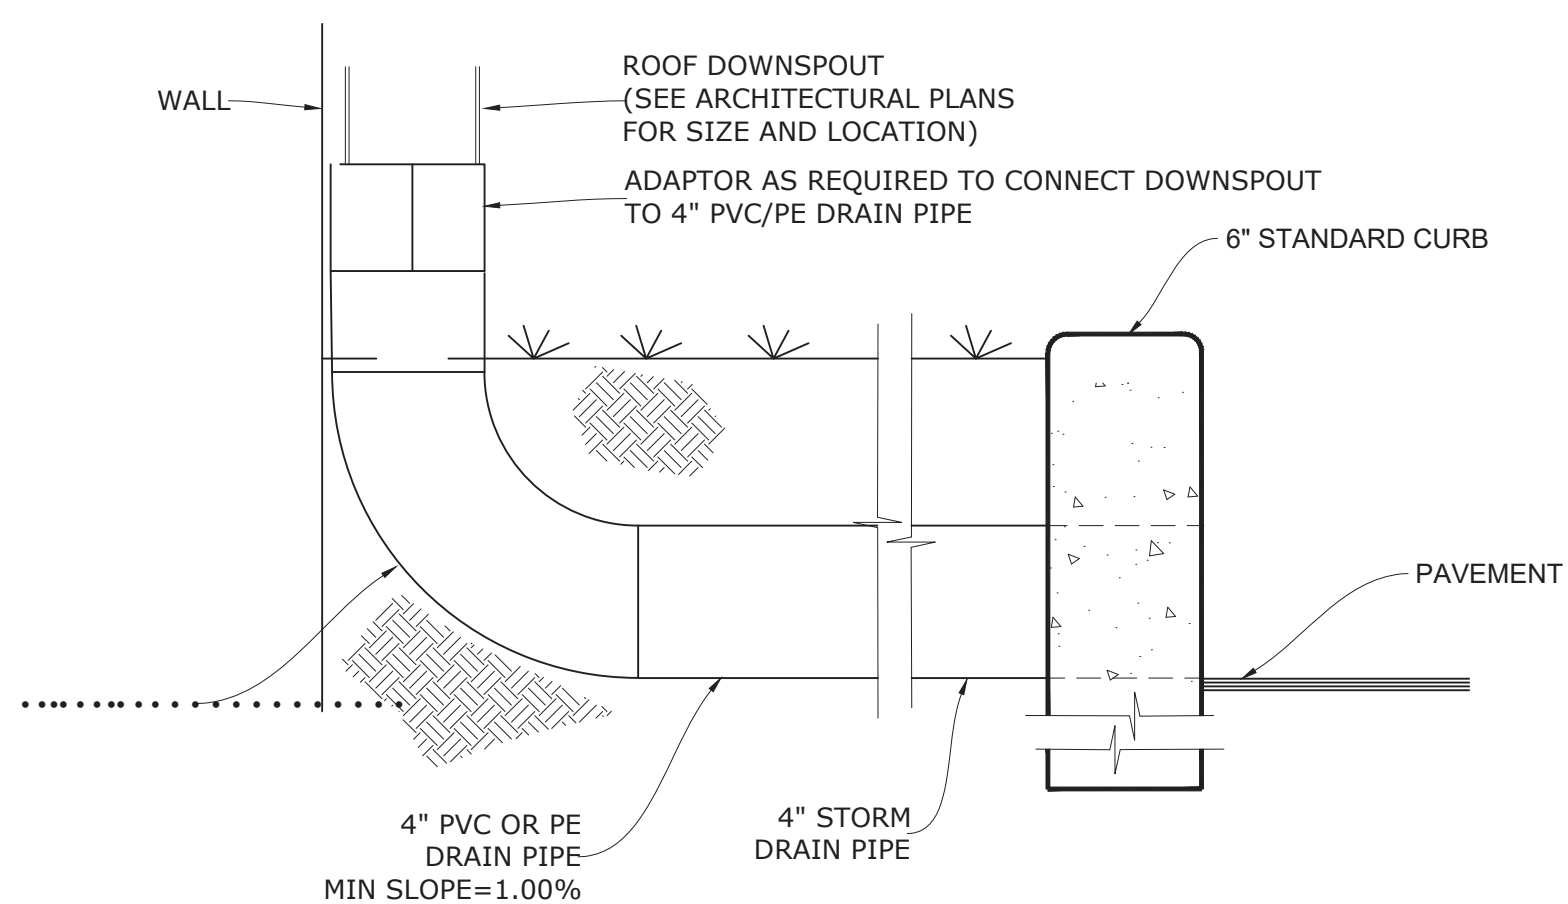


DOWNSPOUT DRAIN CONNECTION DETAIL

N.T.S.

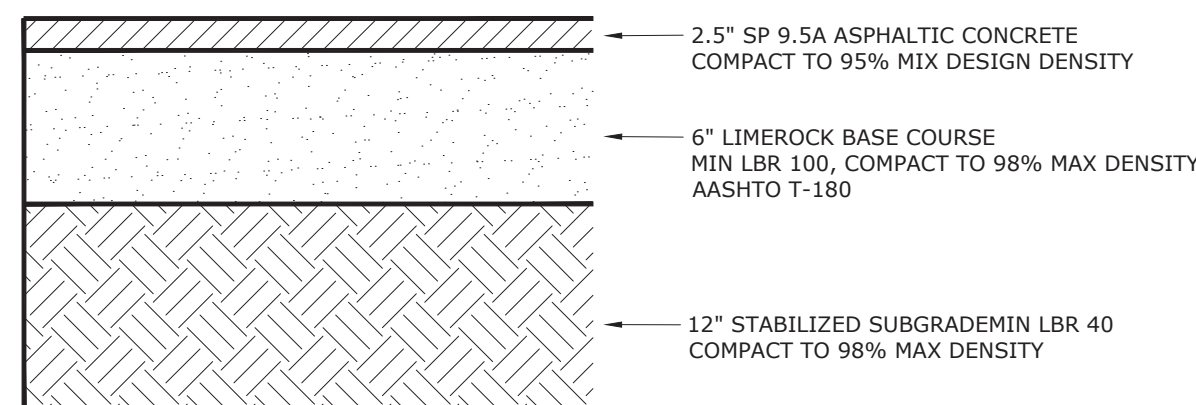


TYPICAL ASPHALT PAVEMENT SECTION

N.T.S.

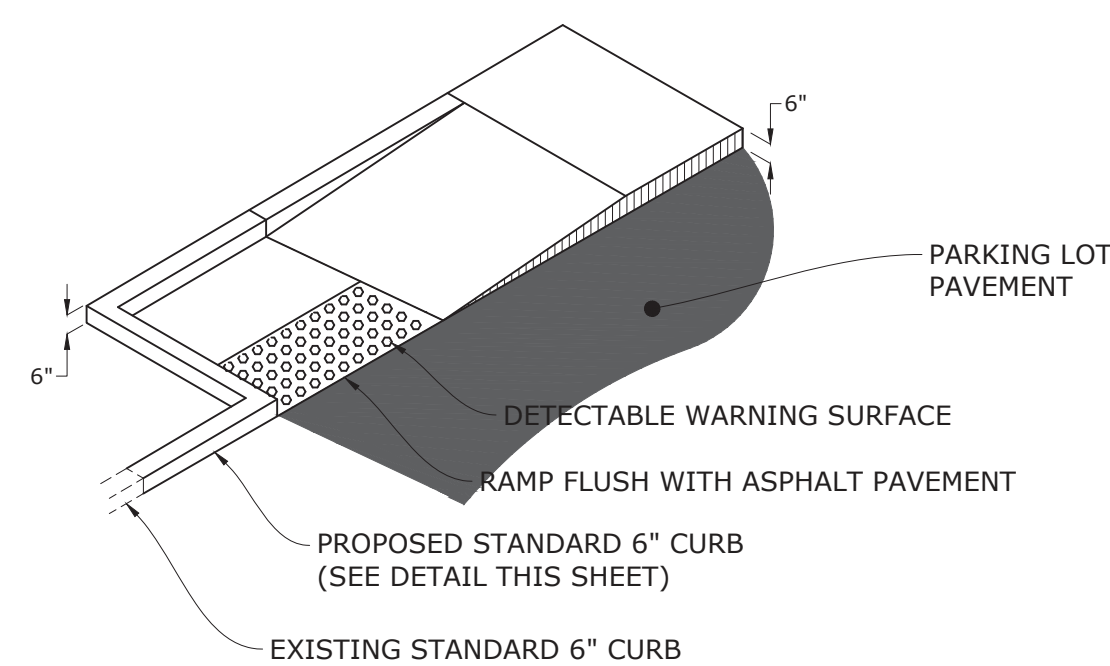


HANDICAP PARKING RAMP DETAIL

N.T.S.

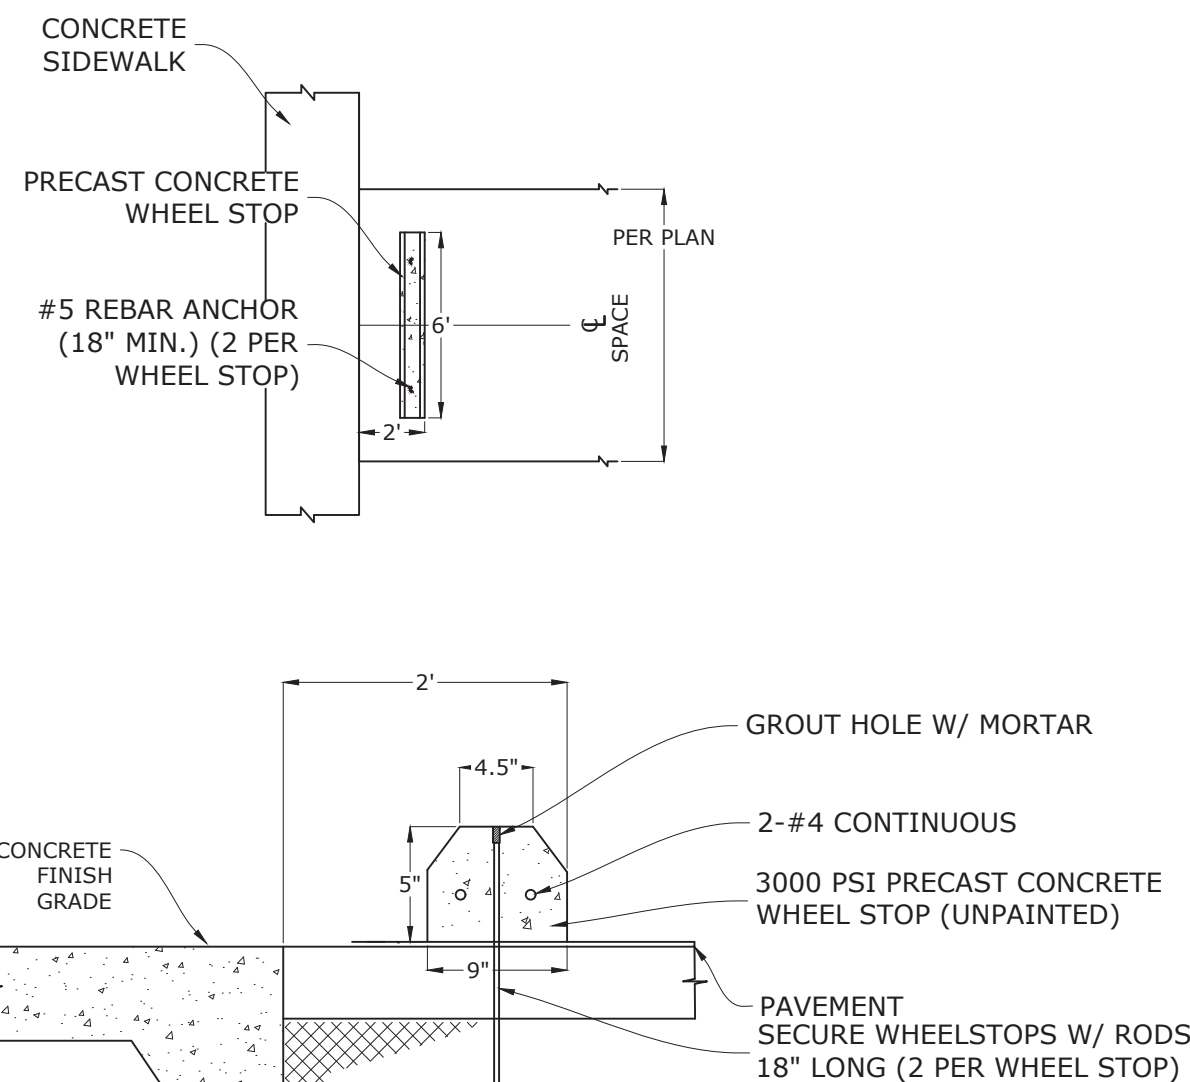


WHEELSTOP DETAIL

N.T.S.

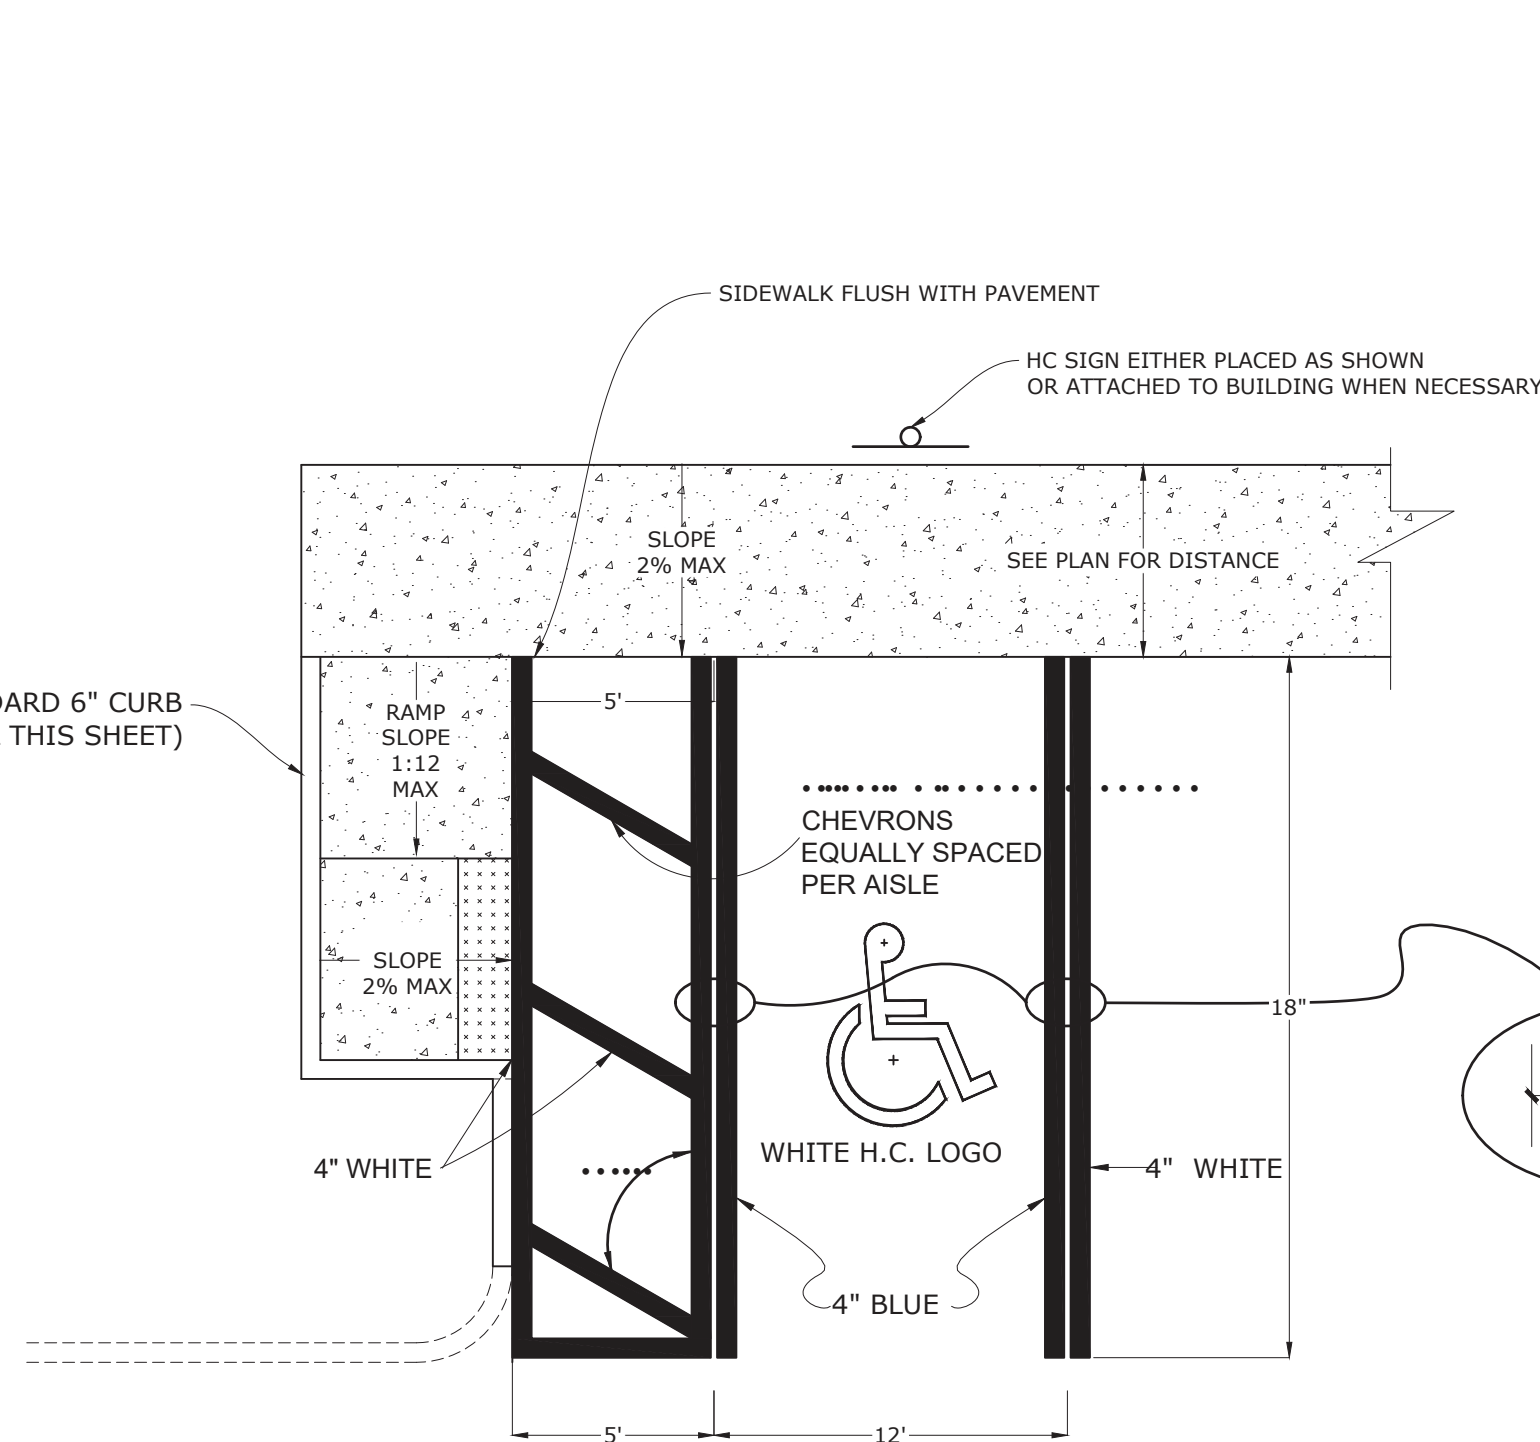

H.C. PARKING STRIPING DETAIL

N.T.S.

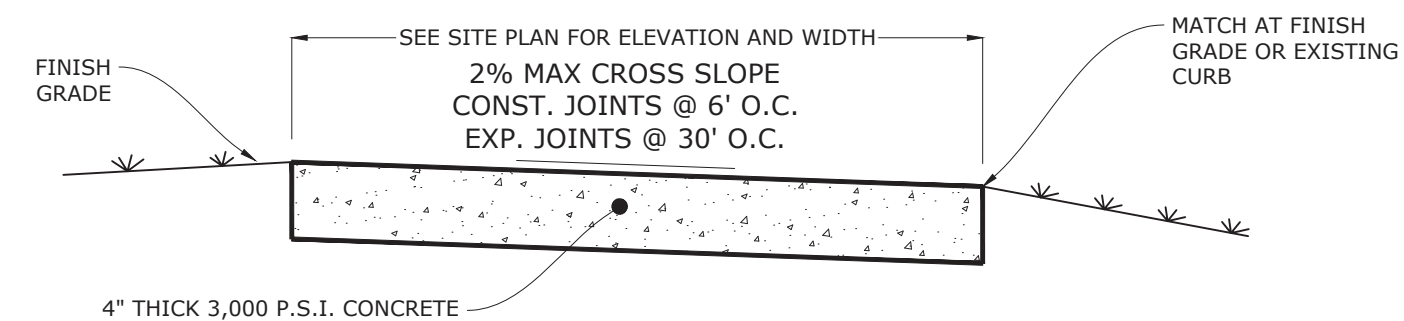


NOTES:

1. THE SIDEWALK SHALL BE CONSTRUCTED ON A CLEAN SAND SUB-BASE COMPACTED TO 95% MAX DENSITY.
2. SAWCUT CONTROL JOINTS SHALL BE CONSTRUCTED 5 FEET ON CENTER.
3. FULL DEPTH TRANSVERSE EXPANSION JOINTS WITH PREFORMED JOINT FILLER SHALL BE CONSTRUCTED AT 30' FEET ON CENTER.


TYPICAL SIDEWALK DETAIL

N.T.S.

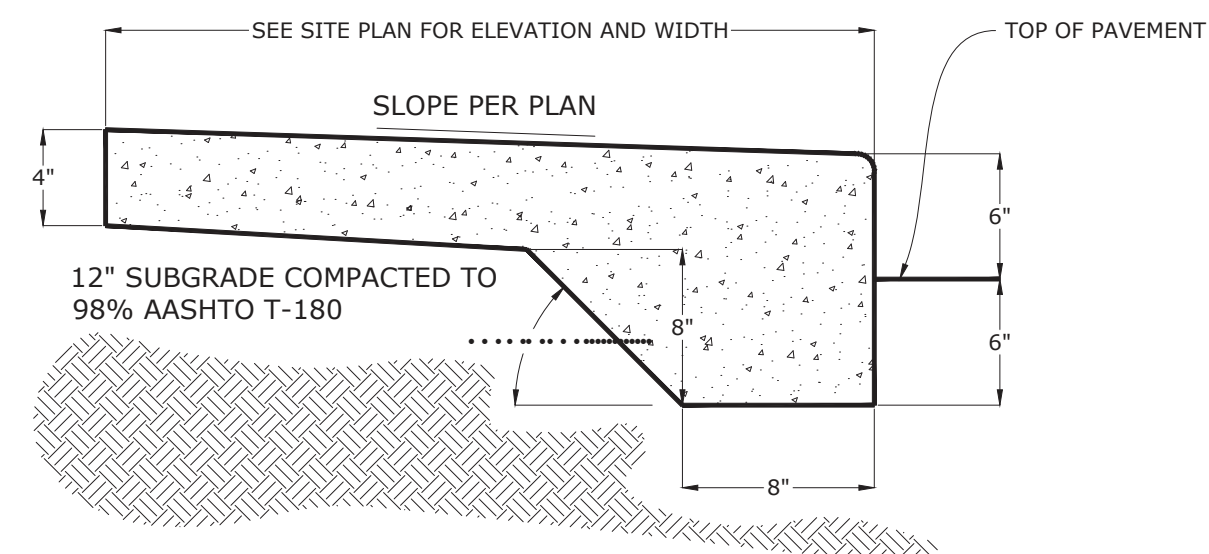


SIDEWALK DETAIL WITH THICKENED EDGE (ADJACENT TO PARKING)

N.T.S.

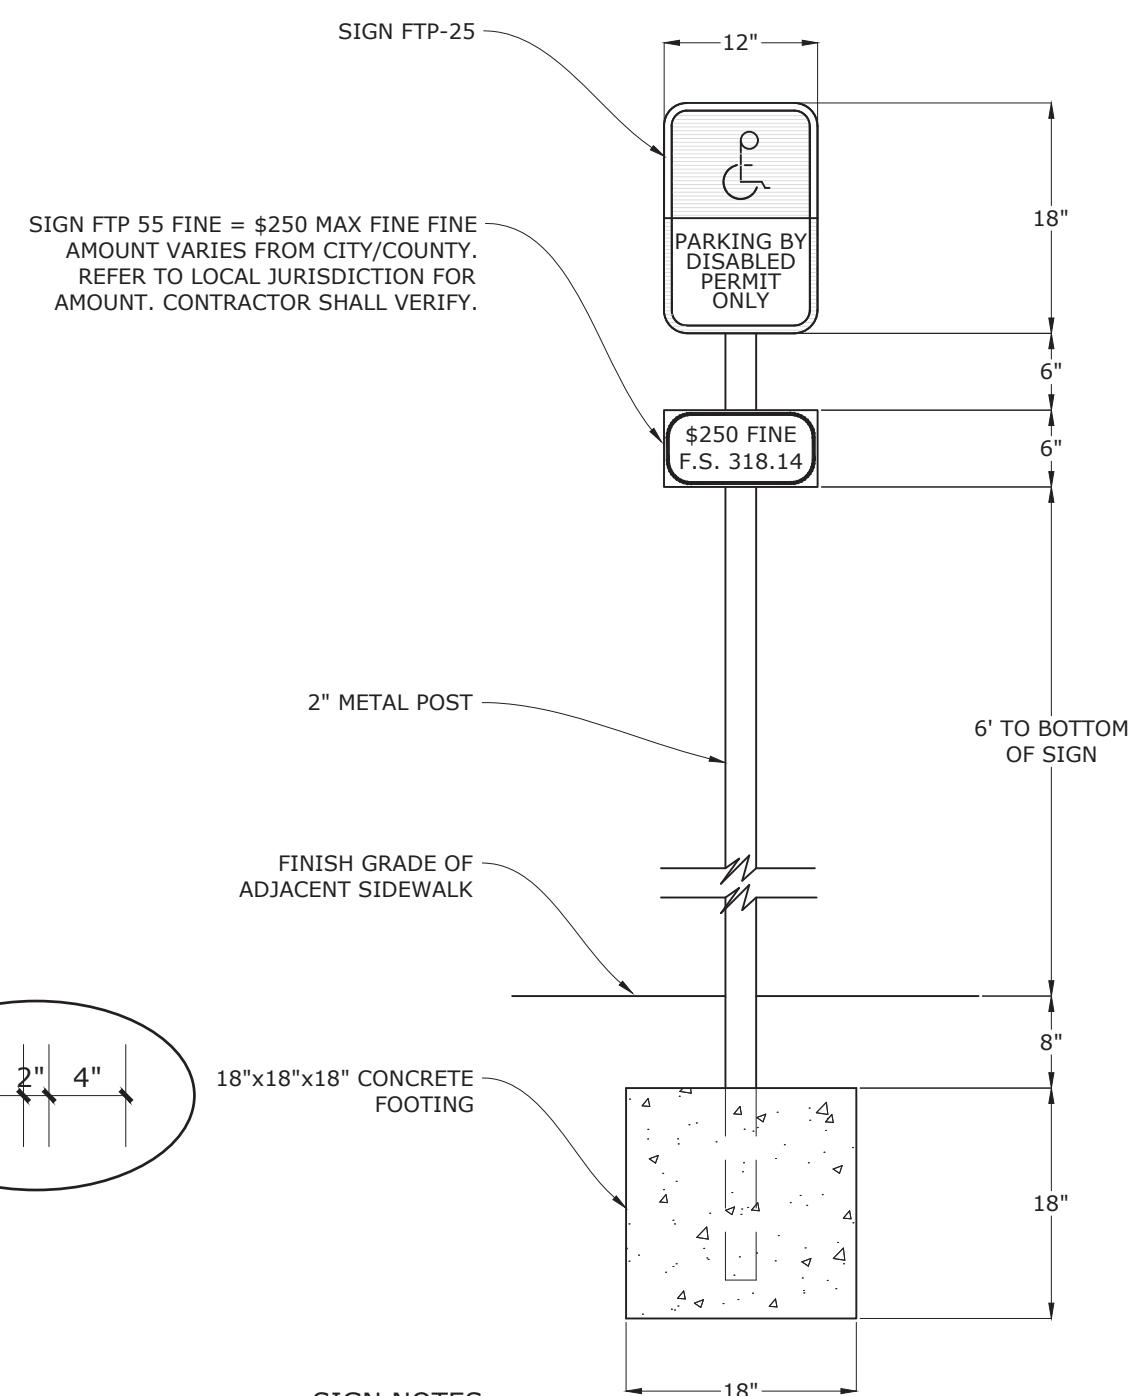

HANDICAP PARKING SIGN

N.T.S.

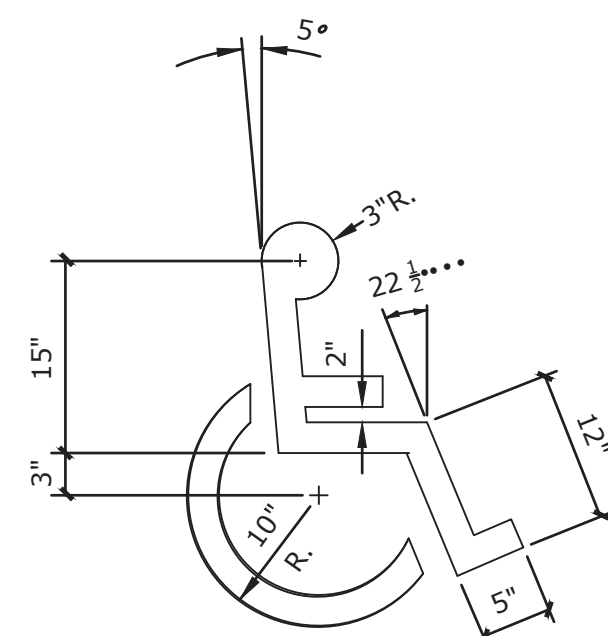


NOTE:
AT HANDICAP PARKING SPACES PROVIDE 4" WIDE BLUE STRIPES 2" INSIDE AND 4" WIDE WHITE PARKING SPACE STRIPES AT EA. SIDE OF H.C. SPACE TYP.

HANDICAP PARKING LOGO


N.T.S.

SHEET NO.		C200			
SHEET TITLE		ICHTETUCKNEE SPRINGS STATE PARK 12087 SOUTHWEST U.S. 27, FORT WHITE, FL 32038			
CONSTRUCTION DETAILS					
PROFESSIONAL REGISTRATION FLORIDA ENGINEER #78674		CONSULTANT : DRMP ENGINEERS • SURVEYORS • PLANNERS • ARCHITECTS Certificate of Authorization No. 2648 Tallahassee, Florida 32317 Phone: 850.562.9500 WWW.DRMP.COM			
DESIGNER : BRL		ISSUE DATE: 6/5/2023	SYMBOL	REVISION	DATE
DRAWN BY: RAJ		COMP. FILE No.: 14-0210.038			
REVIEWED BY: RRC		STATE PROJECT No.: 61363C			
		<i>Department of Environmental Protection</i> <i>Office of Operations</i> <i>Bureau of Design and Construction</i> <i>3800 Commonwealth Blvd., Tallahassee, FL 32399 (850) 425-2300</i>			
PROJECT TITLE		ICHTETUCKNEE SPRINGS STATE PARK REPLACE RESTROOM			

P:\Projects\14-0210.038_(TA38)_Ichetucknee_Restroom\CADD\14-0210.038_(TA38)_CONSTRUCTION_DETAILS.dwg Plotted: Aug. 14, 2023 -- 11:14am by Blennon

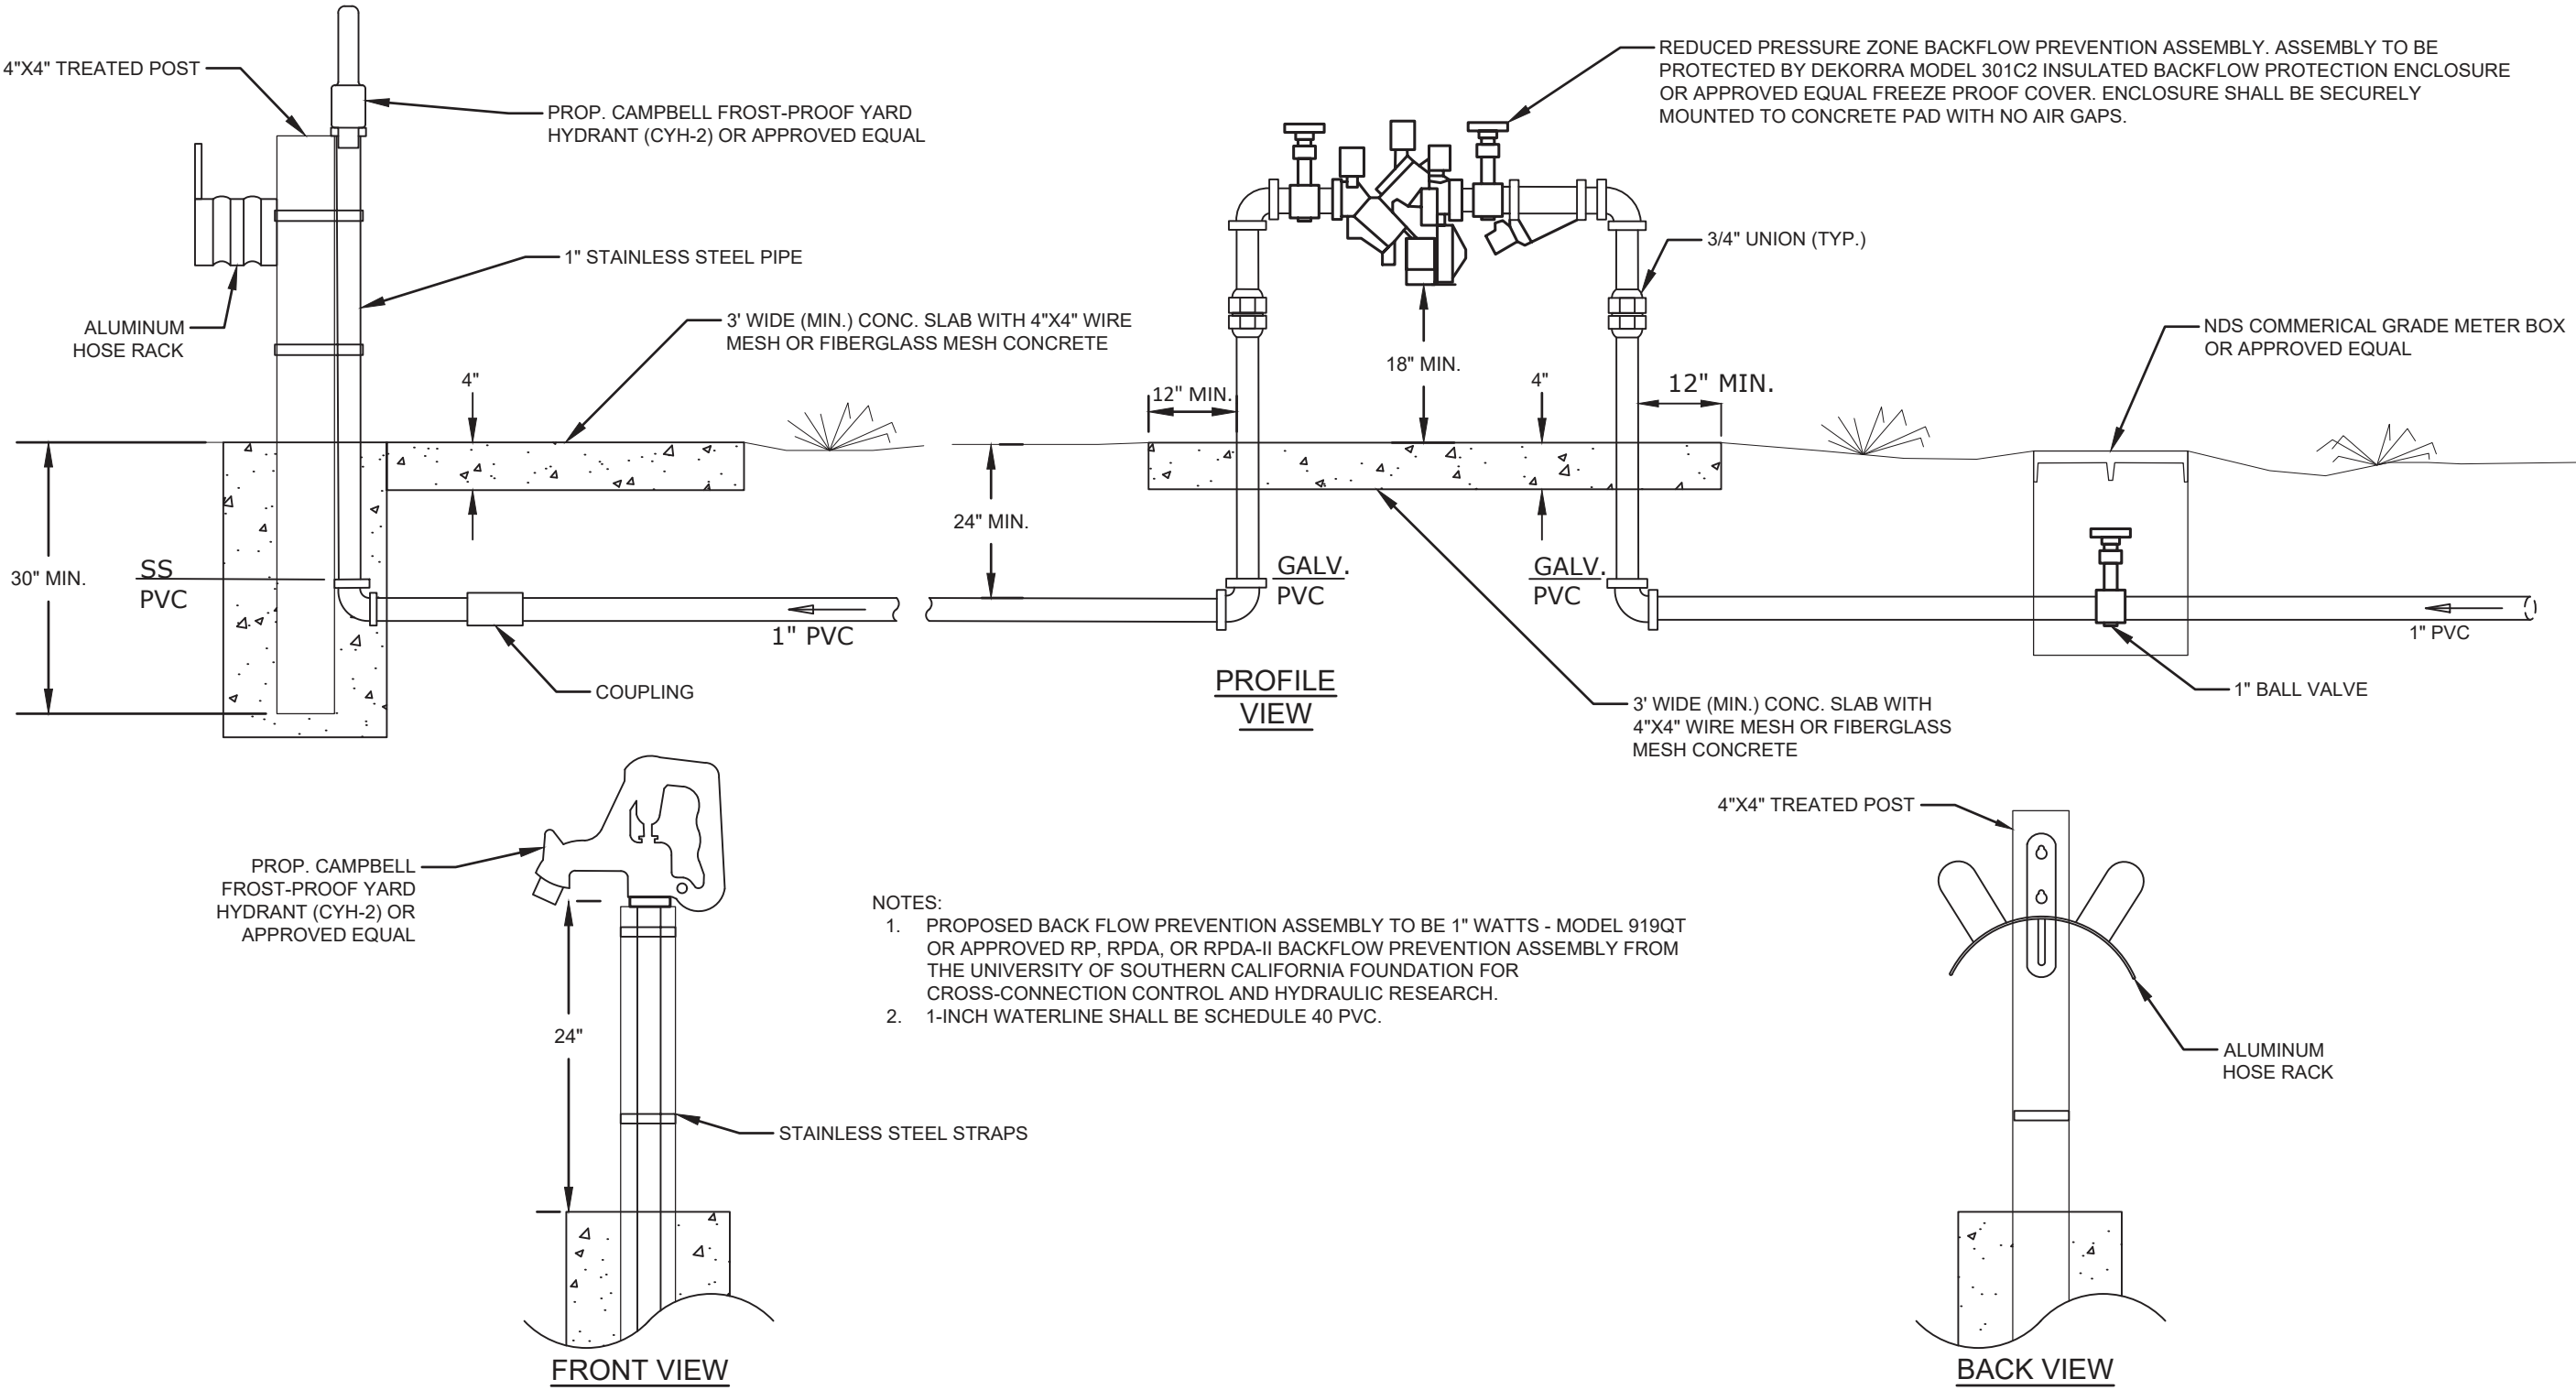

YARD HYDRANT & RPZ DETAILS
N.T.S.

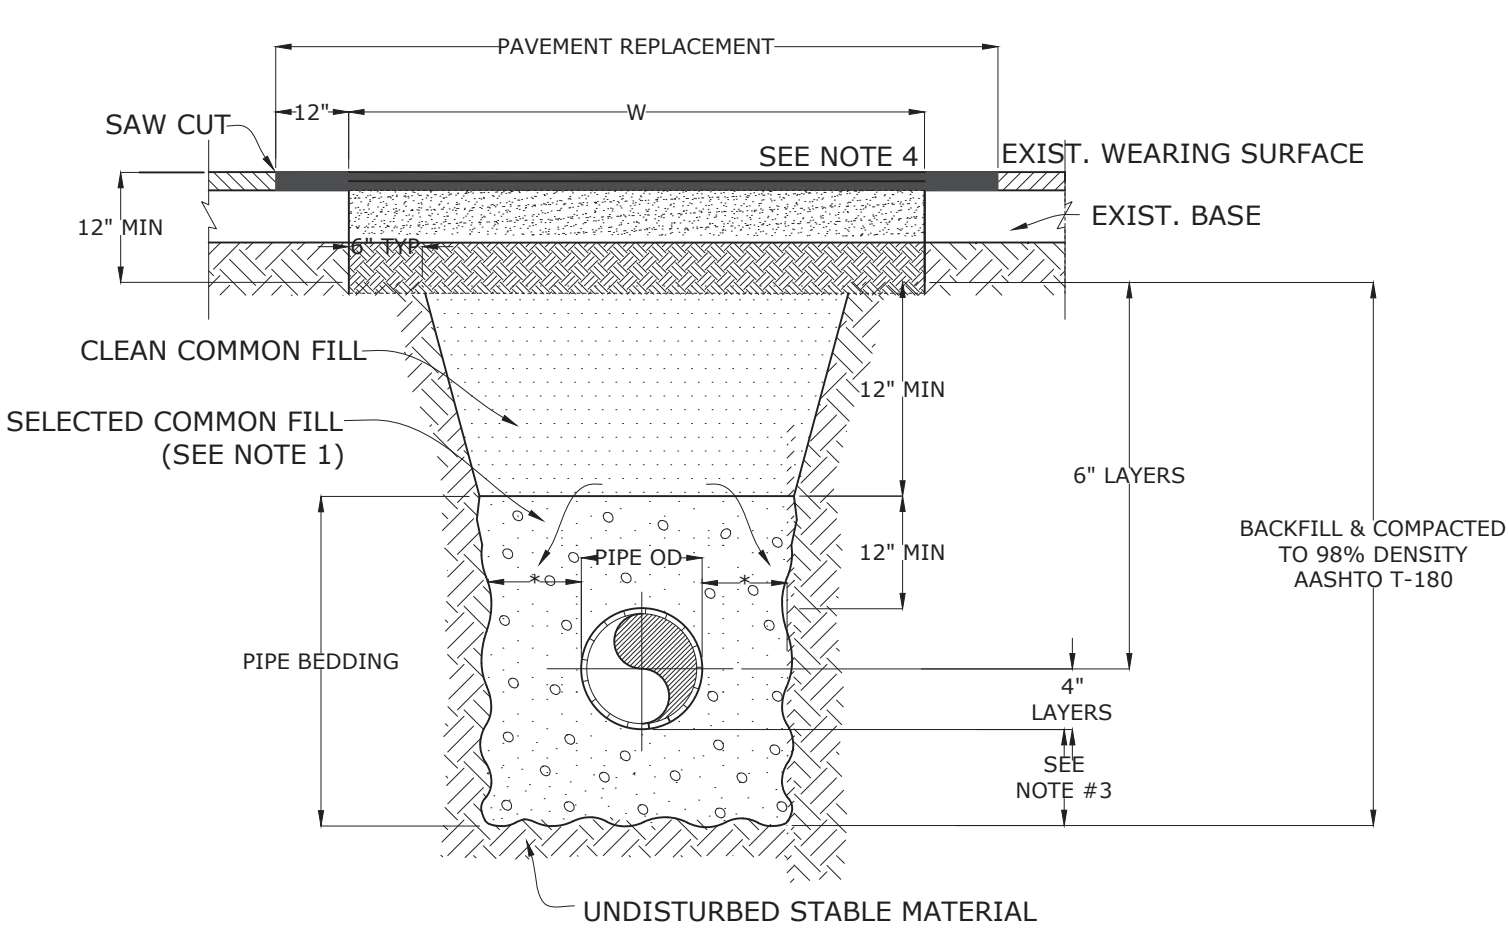

PAVEMENT REPLACEMENT	
DEPTH OF CUT	LIMIT OF PAVEMENT MAXIMUM WIDTH "W"
0'-8"	13'
8'-12'	21'
12'-16'	29'
16'-20'	32'

THIS TABLE IS FOR PAYMENT PURPOSES ONLY. SAFETY REQUIREMENTS MAY DICTATE INCREASED WIDTHS.

- NOTES:
- USE OF TYPE A-2 AND A-3 PIPE BEDDING TO BE DETERMINED IN THE FIELD BY THE ENGINEER.
 - 10" MAX. FOR PIPE DIAMETER LESS THAN 24"
 - 4" MAX. FOR PIPE 15" DIAMETER AND LESS
 - SEE TYPICAL ASPHALT SECTIONS SHEET C200.
 - BASE MATERIAL SHALL BE D.O.T. NO. 57, LIMEROCK, SHELL OR APPROVED EQUAL.
 - BACKFILL AASHTO M-145 SHALL BE PLACED IN LAYERS NOT TO EXCEED 6 INCHES. EACH LAYER SHALL BE THOROUGHLY TAMPED AND/OR ROLLED TO 98% AASHTO T-180 DENSITY.
 - TEMPORARY PATCHES WILL BE MAINTAINED SO AS TO PROVIDE A SMOOTH ALL WEATHER SURFACE AT ALL TIME. PERMANENT PATCH TO BE MADE AS SOON AS POSSIBLE.

OPEN CUT PAVEMENT REPAIR DETAIL
N.T.S.

SHEET NO.		C201	
PROJECT TITLE ICHETUCKNEE SPRINGS STATE PARK REPLACE RESTROOM		SHEET TITLE CONSTRUCTION DETAILS	
PROFESSIONAL REGISTRATION BENJAMIN R. LENNON, P.E. FLORIDA ENGINEER #75674		DESIGNER : BRL DRAWN BY: RAJ REVIEWED BY: RRC Consultant :	
ISSUE DATE: 6/5/2023 COMP. FILE NO.: 14-0210.038 STATE PROJECT NO.: 61363C		DATE REVISION SYMBOL DATE REVISION SYMBOL DATE REVISION SYMBOL	
Department of Environmental Protection Office of Operations Bureau of Design and Construction 3800 Commonwealth Blvd., Tallahassee, FL 32399 (850) 425-2300		DRMP TALLAHASSEE DIVISION 1825 SUMMIT LAKE DRIVE TALLAHASSEE, FLORIDA 32317 PHONE: 850.622.9600 WWW.DRMP.COM	

DIMENSIONS ON THIS SITE PLAN ARE AS PROVIDED TO
ENGINEER. ALL DIMENSIONS SHOULD BE CONFIRMED
PRIOR TO CONSTRUCTION. ENGINEER ASSUMES NO
LIABILITY FOR USE OF THESE DRAWINGS FOR
PURPOSES OTHER THAN PERMITTING.

The site plan shows a rectangular area labeled "PROPOSED RESTROOM" in the upper left. To its right is a parking area with several rectangular stalls. A curved line, likely a road or boundary, runs horizontally across the middle. Below this line are several circular features of varying sizes, some of which are overlapping. To the right of the curved line is a small building with a chimney, and further right is a long, narrow rectangular area with vertical lines, possibly a fence or a series of plantings. The text "FM" is written near the building and the long rectangular area.

PROPOSED
RESTROOM

FM

FM

SCALE: 1" = 20'

DRAINFIELD SIZING	3000 gpd / 0.8 LTAR TRENCH	= 3,750 s.f.
2 ZONES x	8 laterals @ 80' ea x 3' PTI eq	= 3,840 s.f.
DOSING	Network Volume x 4 =	210 gallons/dose minimum
3,000 gpd /	5 doses/day	600 gallons/dose OKAY
<u>DISCHARGE SPECIFICATIONS</u>		
Lateral length and quantity	80 feet each lateral	8 laterals per DOSE
1-1/4" Lateral Feed	END	
Orifice size	1/2" facing up	last hole faces down
Spacing	8' apart;	begin 6' from end
Orifices per lateral	10	80 orifices per DOSE
<u>DISTRIBUTION NETWORK</u>		
Force main	2" PVC	
Header, center feed	2" PVC	
Pump: Use Goulds	WS07B	

All pipe and fittings shall be Sch 40 PVC
All connections shall be deburred, primed, and solvent welded per industry standard
Provide threaded cleanouts at ends of laterals, extend access to surface. (See Detail)

NEW RESTROOM BUILDING 3000 gpd design
c) TREATMENT UNIT: MicroFAST 1.5, no equals
DRAINFIELD SIZING: 3750 s.f. MIN
DRAINFIELD REDUCTION: NONE
SETBACK REDUCTIONS: NONE
LOT LOADING INCREASE: NONE

I, Mark D Repasky, PE0036872, do hereby certify that the unit(s) used in this system design is capable of consistently meeting, at minimum, secondary treatment standards established by for CBO₂ and TSS established in Rule 62-6.025(12)(a), FAC.


In addition, the following requirements shall also be met:

The system installation shall be inspected and approved by the design Engineer (62-6.003(2)(c)1., FAC) prior to use of the system.

The owner or lessee of a system shall continuously comply with the applicable safety, maintenance and operational requirements of 62-6.025(2). FAC as well as manufacturer and design engineer recommendations.

This system requires a maintenance agreement with a permitted aerobic unit maintenance entity which has at least a Class D state certified operator who has been certified under the provisions of Chapter 62-062, FAC.


Sampling for effluent quality reports for CBO₂ and suspended solids shall be collected at least semi-annually and such samples shall be analyzed by a department-approved laboratory.

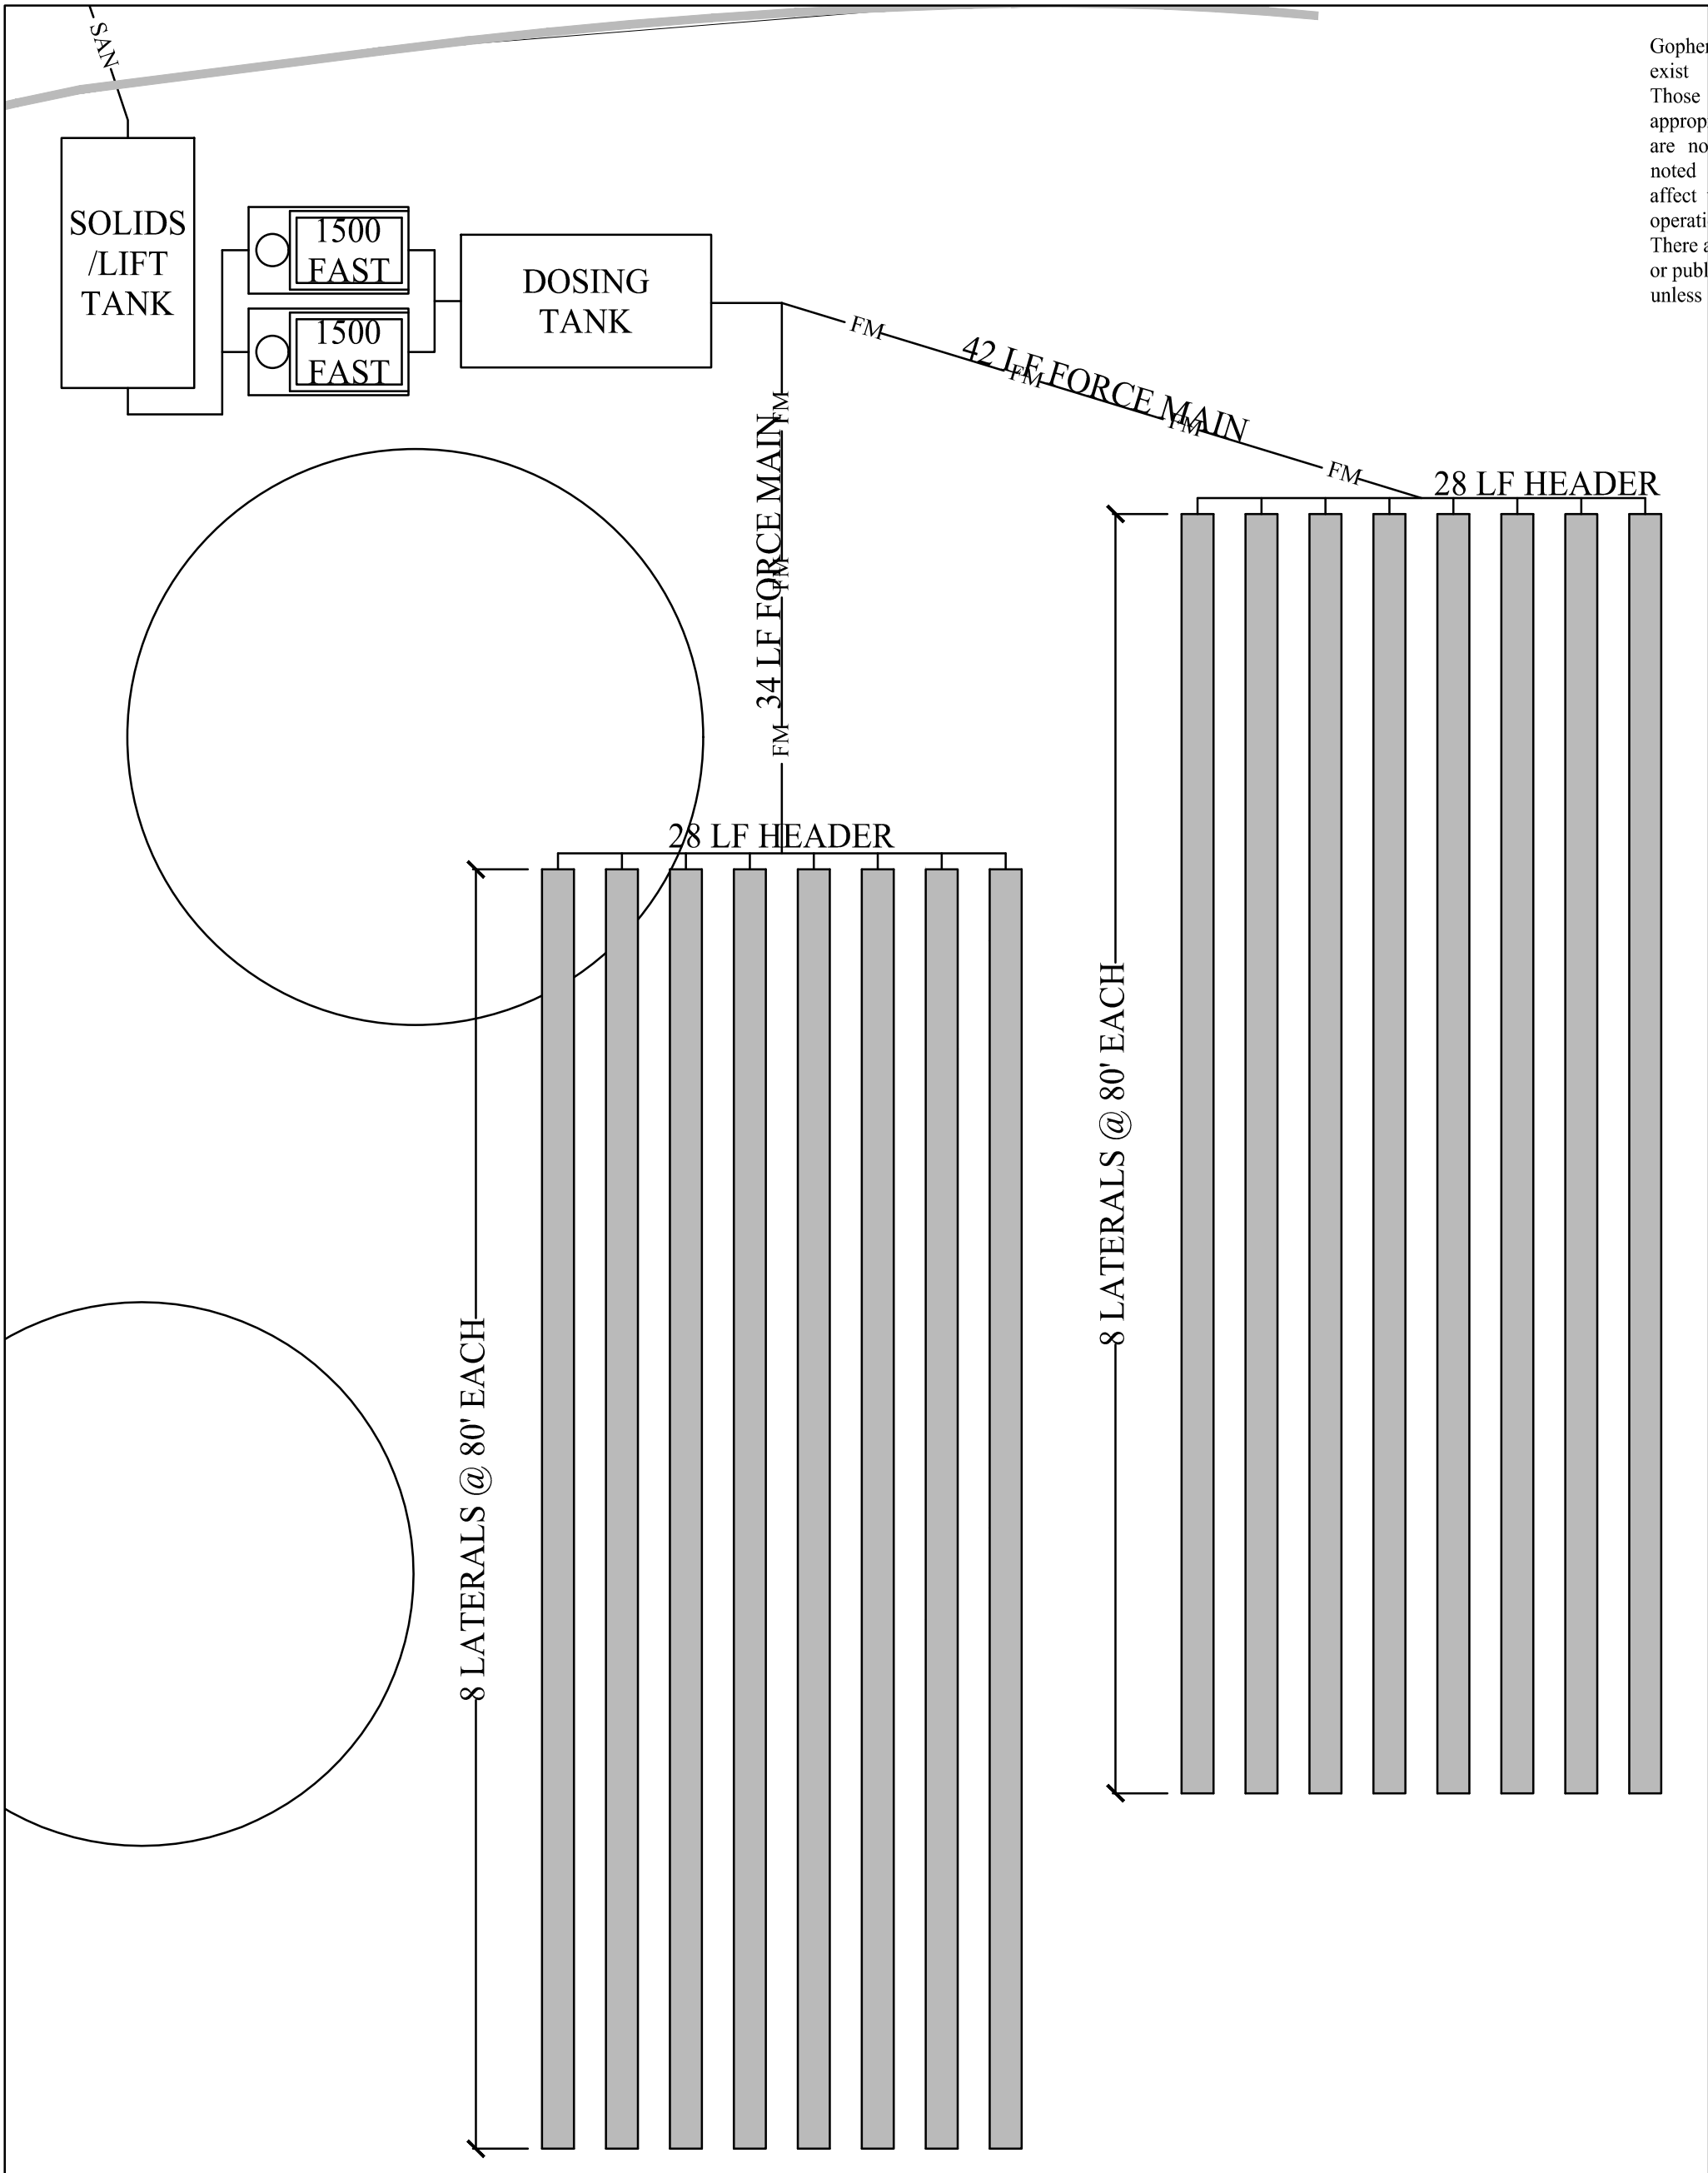


Gopher tortoise burrows likely exist in the drainfield area. Those will need to be appropriately relocated. There are no other pertinent features noted near the site that would affect the system installation or operation. There are no known onsite wells or public wells within 200 feet unless shown.

SHEET NO.	12087 SOUTHWEST U.S. 27, FORT WHITE, FL 32038	19 OCTOBER 2022	DESIGNER : DRAWN BY: REVIEWED BY:	ISSUE DATE: 9/28/2022	SUBMITAL	REVISION	REVISION	DATE			
				COMP. FILE NO.: 14-0210.038	A	C					
SHEET TITLE			STATE PROJECT NO.: 61363C			DATE					
WASTEWATER TREATMENT SYSTEM SITE PLAN			CONSULTANT :								
PROJECT TITLE			MARK D. REPASKY, FID#00075, SBO#11699 WASTEWATER TECHNOLOGIES, Inc. 2000 S. GOLF COURSE RD. CAZ7504 S#008154 3096 S. ADAMS STREET, TALLAHASSEE, FL 32317 850-564-1111 850-565-5555 FAX 850-564-1111 850-565-5555 FAX			DRMP ENGINEERS • ARCHITECTS • PLANNERS • SCIENTISTS Certified Professional Engineer No. 2648 1625 W. Highway 90 Tallahassee, Florida 32317 Phone 850-562-9600 WWW.DRMP.COM			Department of Environmental Protection Office of Operations Bureau of Design and Construction 3800 Commonwealth Blvd., Tallahassee, FL 32399 (850) 425-2300		
ADD RESTROOM											


DIMENSIONS ON THIS SITE PLAN ARE AS PROVIDED TO ENGINEER. ALL DIMENSIONS SHOULD BE CONFIRMED PRIOR TO CONSTRUCTION. ENGINEER ASSUMES NO LIABILITY FOR USE OF THESE DRAWINGS FOR PURPOSES OTHER THAN PERMITTING.

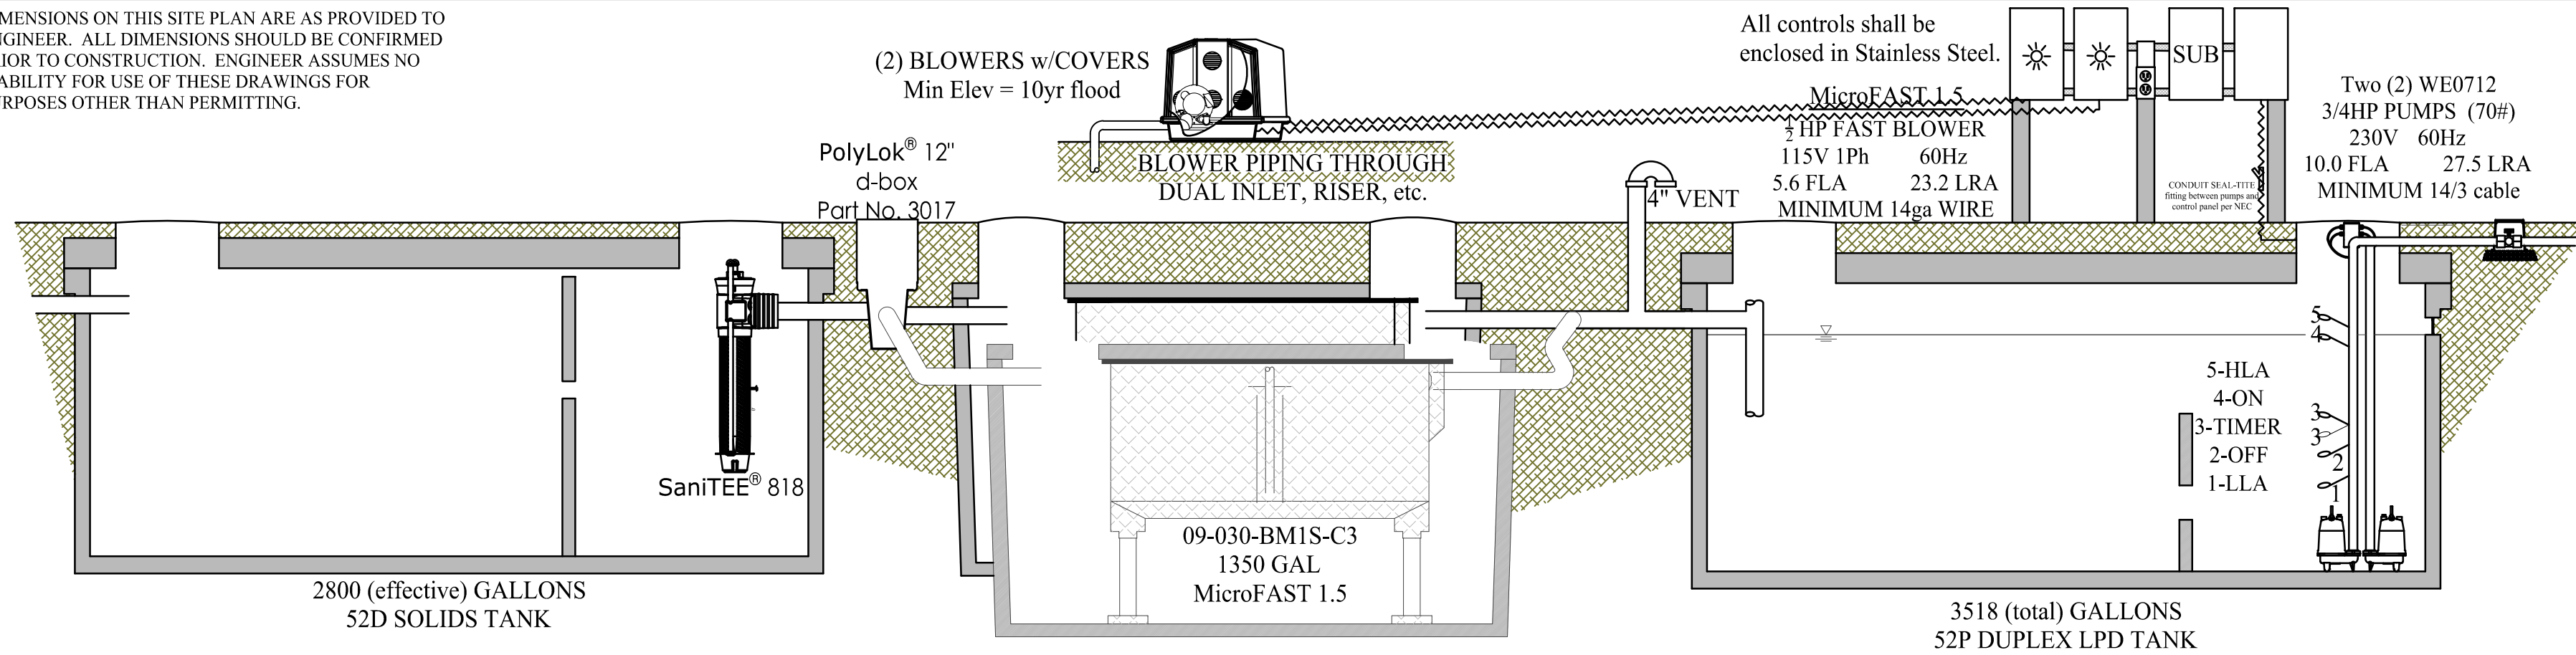

TANK PROFILES
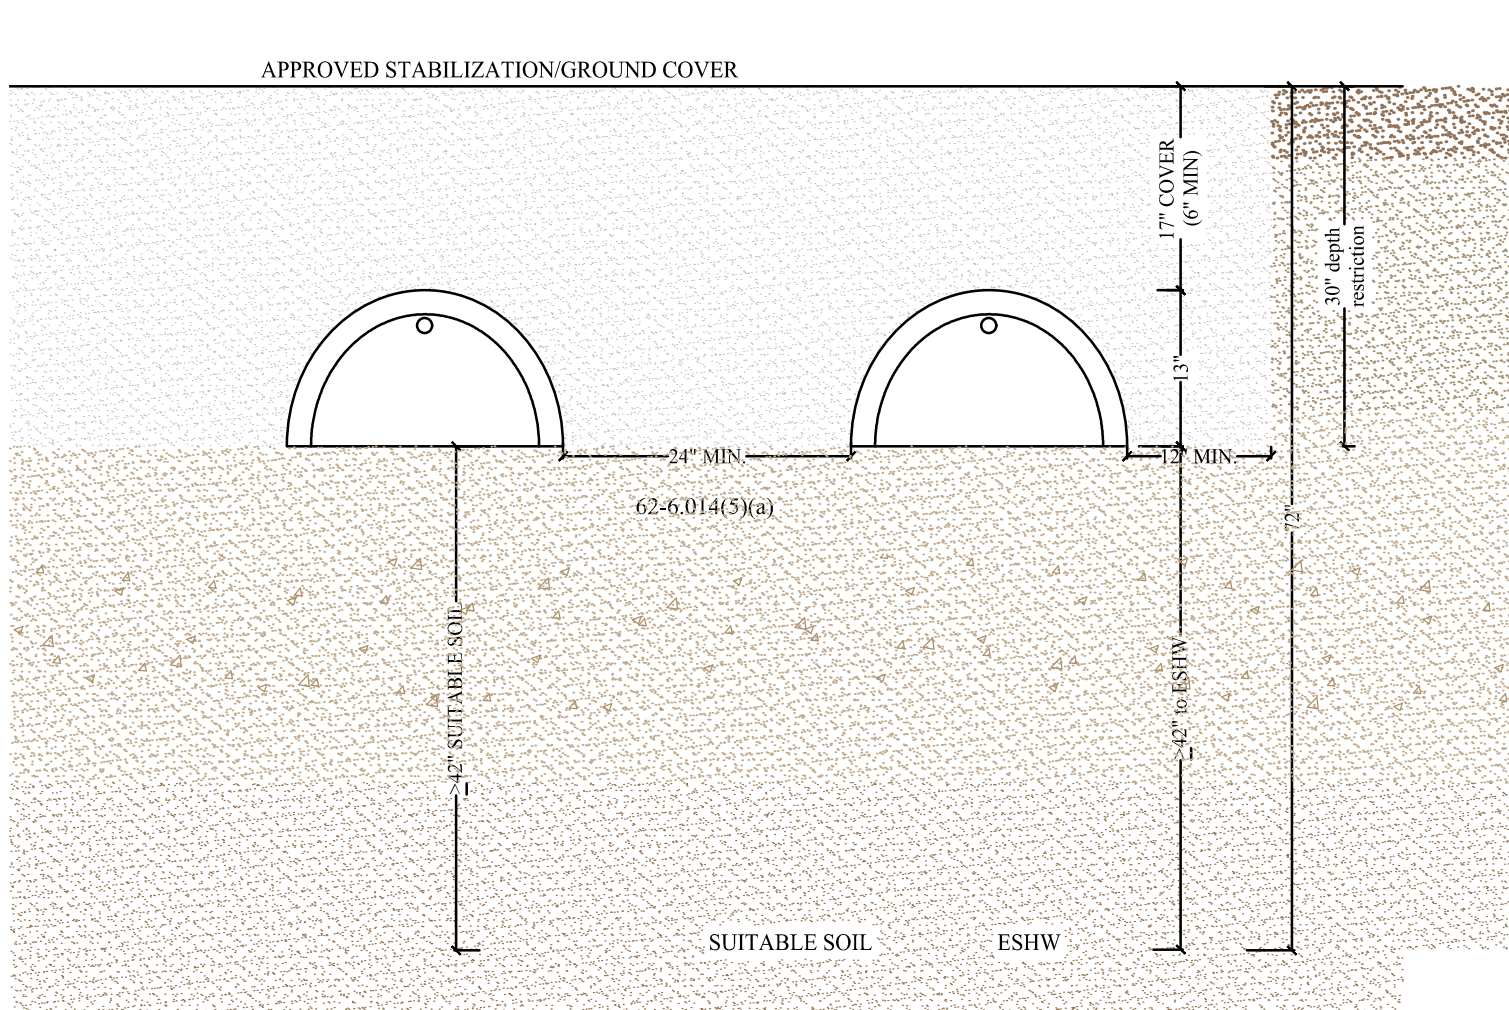
$$c_{100}'' = 1'$$


DRAINFIELD SECTION
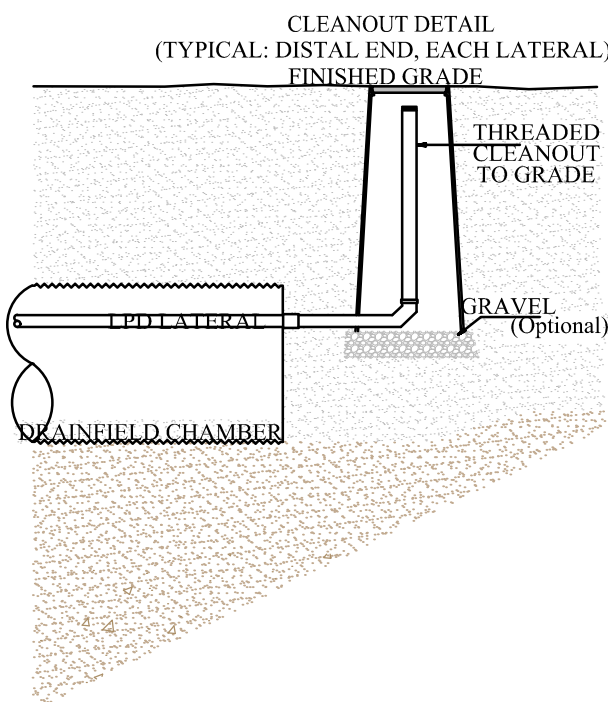
$$x_1' = 1'$$


CERTIFICATION FOR MULTIPLE ATUs TREATING FLOW OVER 1500 gpd

I, Mark D Repasky, PE0036872, do hereby certify that the unit(s) used in this system design is capable of consistently meeting, at minimum, secondary treatment standards established by for CBOD₅ and TSS established in Rule 62-6.025(12)(a), FAC.

In addition, the following requirements shall also be met:

The system installation shall be inspected and approved by the design Engineer (62-6.003(2)(c)1., FAC) prior to use of the system.

The owner or lessee of a system shall continuously comply with the applicable safety, maintenance and operational requirements of 62-6.025(2). FAC as well as manufacturer and design engineer recommendations.

This system requires a maintenance agreement with a permitted aerobic unit maintenance entity which has at least a Class D state certified operator who has been certified under the provisions of Chapter 62-602, FAC.

Sampling for effluent quality reports for CBOD₅ and suspended solids shall be collected at least semi-annually and such samples shall be analyzed by a department-approved laboratory.

CONTROLS

Electrical conduit and effluent dosing pipe is water tight and exits the tank through the tank outlet with a water-tight seal, or through the riser wall, above ESHW, with a soil-tight seal, or through an access port in the tank lid installed by manuf. with a water-tight seal per 62-6.013(9)(c), FAC.

TIMER is allowed as part of this design submitted by this Engineer.

per 62-6.013(9)(d)1., FAC

Control panels shall be as close as practicable to equipment served.

Alarm shall be located in a conspicuous location. When outdoors, alarm shall be waterproof and specified by manufacturer for outdoor use per 62-6.013(9)(d)2, FAC

Controls enclosures shall be STAINLESS STEEL

C203	SHEET NO.	19 OCTOBER 2022	DESIGNER : DRAWN BY: REVIEWED BY:	ISSUE DATE: 9/28/2022 COMP. FILE No.: 14-0210.038 STATE PROJECT No.: 61363C	SYMBOL 	REVISION	DATE
	SHEET TITLE WASTEWATER TREATMENT SYSTEM DETAILS						
PROJECT TITLE ICHTUCKNEE SPRINGS STATE PARK ADD RESTROOM	MARK D. REPASKY, FID#00075, SBO#11699 WASTEWATER TECHNOLOGIES, Inc. CAZ7504 SA008154 3096 S ADAMS STREET, TALLAHASSEE, FLORIDA 32317 850-561-1111 / 850-395-1837 fax	DRMP ENGINEERS • ARCHITECTS • PLANNERS • SCIENTISTS Certified by Authorization No. 264B 1625 W. Highway 90 Tallahassee, Florida 32317 Phone 850-562-9600 WWW.DRMP.COM			<i>Department of Environmental Protection</i> Office of Operations <i>Bureau of Design and Construction</i> 3800 Commonwealth Blvd., Tallahassee, FL 32309 (850) 425-2300		

INDEX OF DRAWINGS

G103	INDEX, GENERAL NOTES, CODE INFO, ABBREVIATIONS, LEGENDS		
LS101	RESTROOM BUILDING - LIFE SAFETY PLAN		
STRUCTURAL			
S001	STRUCTURAL NOTES		
S101	FOUNDATION PLAN		
S201	ROOF FRAMING PLAN		
S301	FOUNDATION DETAILS		
S302	TYPICAL BUILDING SECTION		
S401	TYPICAL MASONRY DETAILS		
ARCHITECTURAL			
A100	ARCHITECTURAL SPECIFICATIONS		
A101	RESTROOM BUILDING - FLOOR PLAN		
A102	RESTROOM BUILDING - FLOOR PLAN - PLUMBING		
A201	RESTROOM BUILDING - REFLECTED CEILING PLAN		
A301	BUILDING ELEVATIONS		
A401	RESTROOM BUILDING - BUILDING & WALL SECTIONS		
A501	RESTROOM BUILDING - ROOF PLAN		
		MECHANICAL	
		M001	LEGEND, NOTES & SCHEDULES - HVAC
		M101	FLOOR PLAN - MECHANICAL
		M501	DETAILS - MECHANICAL
		PLUMBING	
		P001	LEGEND, NOTES DETAILS & SCHEDULES - PLUMBING
		P101	FLOOR PLAN - PLUMBING
		P501	DETAILS & SCHEDULES - PLUMBING
		P601	ISOMETRICS - PLUMBING
		ELECTRICAL	
		E001	LEGEND & NOTES - ELECTRICAL
		E101	FLOOR PLANS - ELECTRICAL
		E501	DETAILS - ELECTRICAL

THE PLANS ARE FOR INFORMATIONAL PURPOSES ONLY. CONTRACTOR SHALL FIELD VERIFY ALL DIMENSIONS AND ALL CONDITIONS. IF THE CONTRACTOR IS UNABLE TO INTERPRET THE CONSTRUCTION DOCUMENTS, HE/SHE IS RESPONSIBLE FOR REQUESTING CLARIFICATION IN WRITING TO THE ARCHITECT. IF THE CONTRACTOR PROCEEDS WITH ANY WORK BEFORE OBTAINING CLARIFICATION, HE/SHE SHALL BE HELD RESPONSIBLE FOR ALL DEFICIENCIES ASSOCIATED THERE.

DIMENSIONS ARE TAKEN FROM THE FACE OF EXISTING NON AND LOAD BEARING INTERIOR WALLS AND FROM THE FACE OF STUD FOR NEW WALLS.

BEFORE SUBMITTING FOR WORK OR BEGINNING WORK, THE CONTRACTOR WILL BE HELD TO HAVE EXAMINED THE PREMISES AND SATISFIED HIMSELF/HERSELF AS TO THE EXISTING CONDITIONS UNDER WHICH HE/SHE WILL BE OBLIGATED AND COMPLETE THE WORK UNDER THE CONTRACT. NO ALLOWANCE WILL BE MADE SUBSEQUENTLY IN THIS CONNECTION ON BEHALF OF THE CONTRACTOR FOR ANY ERRORS OR NEGLIGENCE ON HIS/HER PART.

CONTRACTOR SHALL ERECT AND MAINTAIN ALL REASONABLE SAFEGUARDS FOR SAFETY AND HEALTH INCLUDING POSTING DANGER SIGNS, AND OTHER WARNING AGAINST HAZARDS, AS WELL AS PROMULGATING SAFETY REGULATIONS. CONTRACTOR SHALL PROVIDE SAFETY PRECAUTIONS AND BARRICADES FOR PEDESTRIANS AT CONSTRUCTION, VEHICLE ACCESS AND EGRESS LOCATIONS.

THE CONTRACTOR SHALL SUBMIT A COMPLETE DETAILED CONSTRUCTION SCHEDULE AND PLAN PRIOR TO THE PRE-CONSTRUCTION CONFERENCE.

CONTRACTOR SHALL BE RESTRICTED TO AREAS SPECIFIED BY OWNER FOR ON SITE STORAGE OF CONSTRUCTION MATERIALS. COMPARTMENT TRAILERS OR SIMILAR PROTECTIVE STORAGE FACILITIES MAY BE UTILIZED ON SITE TO SECURE ALL EQUIPMENT AND ITEMS REMOVED DURING PROJECT WORK. THE CONTRACTOR IS RESPONSIBLE FOR THE PROTECTION AND SECURITY OF ALL EQUIPMENT AND ITEMS REMOVED.

CONTRACTOR SHALL COORDINATE WITH LOCAL ELECTRICAL POWER AND WATER UTILITY PROVIDERS TO INSTALL NEW SERVICE TO THE SITE PRIOR TO THE START OF CONSTRUCTION.

ALL WORK SHALL COMPLY WITH APPLICABLE OSHA AND EPA REGULATIONS AND GUIDELINES.

INSTALL WORK IN ACCORDANCE WITH THE CODES LISTED ON THE INDEX SHEET. IMMEDIATELY NOTIFY THE ARCHITECT WHEN CONFLICTS OCCUR BETWEEN CODES AND BETWEEN THE CONSTRUCTION DOCUMENTS.

CONTRACTOR SHALL FURNISH AS-BUILT DRAWINGS TO THE ARCHITECT AT COMPLETION OF THE CONSTRUCTION. CHANGES SHALL BE INDICATED CLEARLY BY MECHANICAL DRAFTING METHODS.

CONTRACTOR SHALL MAINTAIN A CLEAN WORK PREMISES AT ALL TIMES AND SHALL CLEAN CONSTRUCTION SITE OF ALL DEBRIS DAILY.

CONTRACTOR SHALL TAKE CARE NOT TO DAMAGE EXISTING SURFACES OUTSIDE THE SCOPE OF WORK AND SHALL BE RESPONSIBLE FOR RETURNING DAMAGED AREAS (MATERIALS, FINISHES, LANDSCAPE, ETC.) TO THEIR ORIGINAL CONDITION. ALL DISTURBED AREAS OF SOIL TO BE SODED. ALL PLANTING REPLACEMENT TO BE GUARANTEED FOR ONE YEAR.

CONTRACTOR SHALL ERECT ALL SAFE GUARDS TO PROTECT ADJACENT AREAS. REMOVE DEBRIS FROM JOB SITE DAILY AND ADHERE TO ENVIRONMENTAL REGULATIONS.

WHERE A NOTE IS SHOWN FOR ONE CONDITION IT SHALL APPLY TO ALL SIMILAR AND LIKE CONDITIONS.

CONTRACTOR SHALL PATCH ALL SPALLED AND ROUGH CONCRETE FLOOR SURFACES TO PROVIDE A CONTINUOUS LEVEL CONCRETE SURFACE.

A DISCOVERY OF ASBESTOS: ALL MATERIAL KNOWN TO CONTAIN ASBESTOS & THAT WILL BE IMPACTED BY DEMOLITION & CONSTRUCTION ACTIVITIES INCLUDED IN THE PROJECT SCOPE OF WORK HAVE BEEN REMOVED. IN THE EVENT CONCEALED CONDITIONS ARE ENCOUNTERED, NOTIFY THE ARCHITECT PRIOR TO PROCEEDING FURTHER WITH WORK.

A KNOX BOX SHALL BE INSTALLED ON THE EXTERIOR OF THE BUILDING WITHIN 5' OF THE MAIN ENTRANCE DOOR. MOUNTING HEIGHT TO BE NOT GREATER THAN 5' AFF. KEYS TO BUILDING, PHASE I AND PHASE II ELEVATOR RECALL SHALL BE PROVIDED FOR PLACEMENT IN KNOX BOX. REQUIRED DUE TO SPRINKLER CONTROL VALVES AND/OR FIRE ALARM CONTROL PANEL LOCATED IN THIS SPACE OR THE BUILDING IS PROVIDED WITH ELEVATOR RECALL. **NFPA 1, 16.2.2.1, FLORIDA 2018 EDITION.**

A MINIMUM 6" ADDRESS NUMBERS SHALL BE LOCATED ON THE EXTERIOR OF THE BUILDING. NUMBERS TO BE PLAINLY VISIBLE FROM THE STREET OR OTHER ELEVATIONS AND CONTRAST WITH BACKGROUND. THIS MAY BE WAIVED IF ADDRESS NUMERIC IS ILLUMINATED ON A SIGN SEPARATE FROM THE BUILDING THAT IS VISIBLE FROM THE STREET. **NFPA 1, 10.11.1, 10.11.1.2 & 10.11.1.7, 10.11.1.8, FLORIDA 2018 EDITION**

THE ELEVATION OF THE FLOOR SURFACE ON BOTH SIDES OF ANY DOOR SHALL NOT VARY BY MORE THAN 1/2" INCH FOR A DISTANCE NOT LESS THAN THE WIDTH OF THE WIDEST LEAF. PLEASE SHOW ON PLANS: **NFPA 101, SECTION 7.2.1.3.1, FLORIDA 2018 EDITION**

CONTRACTOR SHALL MAKE AVAILABLE TO THE BUILDING INSPECTOR DOCUMENTATION NECESSARY TO VERIFY THAT ALL EXTERIOR ENVELOPE COMPONENTS REQUIRING PRODUCT APPROVAL PER FS 553.842 ARE IN COMPLIANCE WITH PRODUCT APPROVAL INSTALLATION REQUIREMENTS

THE FIRE ALARM CONTRACTOR SHALL SUBMIT PLANS FOR EVALUATION AND APPROVAL PRIOR TO COMMENCEMENT OF NEW WORK". FIRE PROTECTION IS NOT PART OF THE BUILDING PERMIT EVALUATION.


ALL GUARDRAILS SHALL RESIST A CONCENTRATED LOAD OF 250 POUNDS; **2020 FBC-8, SECTION 1607.8.1 & 1607.8.1.1**


PROVIDE SIGNAGE
MEETING F.A.C.
69A-60.0081
REQUIREMENTS.

SIGNAGE SHALL
INDICATE LIGHT-FRAME
TRUSS-TYPE ROOF
FRAMING WITH 8"x8"
REFLECTIVE RED
MALTESE CROSS -
VERIFY SPECIFIC
LOCATIONS WITH STATE
FIRE MARSHAL
INSPECTOR - SIGN
TYPICALLY SHALL BE
LOCATED WITHIN 24" TO
THE LEFT OF THE MAIN
ENTRY AND BETWEEN
4'-0" AND 6'-0" A.F.F.






H.B.	HOSE BIBB	V.C.	VITROUS CLAY
H.C.	HANDICAP	V.E.J.	VERTICAL EXPANSION JOINT
HT.	HEIGHT	VENT.	VENTILATION
H.M.	HOLLOW METAL	VERT.	VERTICAL
H.P.	HIGH POINT	V.I.F.	VERIFY IN FIELD
HR.	HOUR	V.T.R.	VENT THRU ROOF
HTG.	HEATING	W.	WATT
H.&V.	HEATING & VENTILATING	W/	WITH
HDWE	HARDWARE	W.C.	WATER CLOSET
HYD.	HYDRANT	W.C.O.	WASTE CLEAN OUT
		WD.	WOOD
I.D.	INSIDE DIAMETER	W.D.	WINDOW DIMENSION
IN.	INCHES	W.G.	WATER GAGE
INCAND.	INCANDESCENT	WP.	WEATHERPROOF
INSUL.	INSULATION	W.W.F.	WELDED WIRE FABRIC
INT.	INTERIOR		

SHEET TITLE 12087 SOUTHWEST U.S. 27, FORT WHITE, FL 32038 ICHETUCKNEE SPRINGS STATE PARK REPLACE RESTROOM		DESIGNER: RAY DOUGLAS SHULER FLAR 90089	DRAWN BY: JHIGHTOWER	DSHULER	ISSUE DATE: 28 MARCH 2023	REVISION SYMBOL DATE	REVISION SYMBOL DATE	DATE
INDEX	PROJECT TITLE ICHETUCKNEE SPRINGS STATE PARK REPLACE RESTROOM							
SHEET NO. G103								

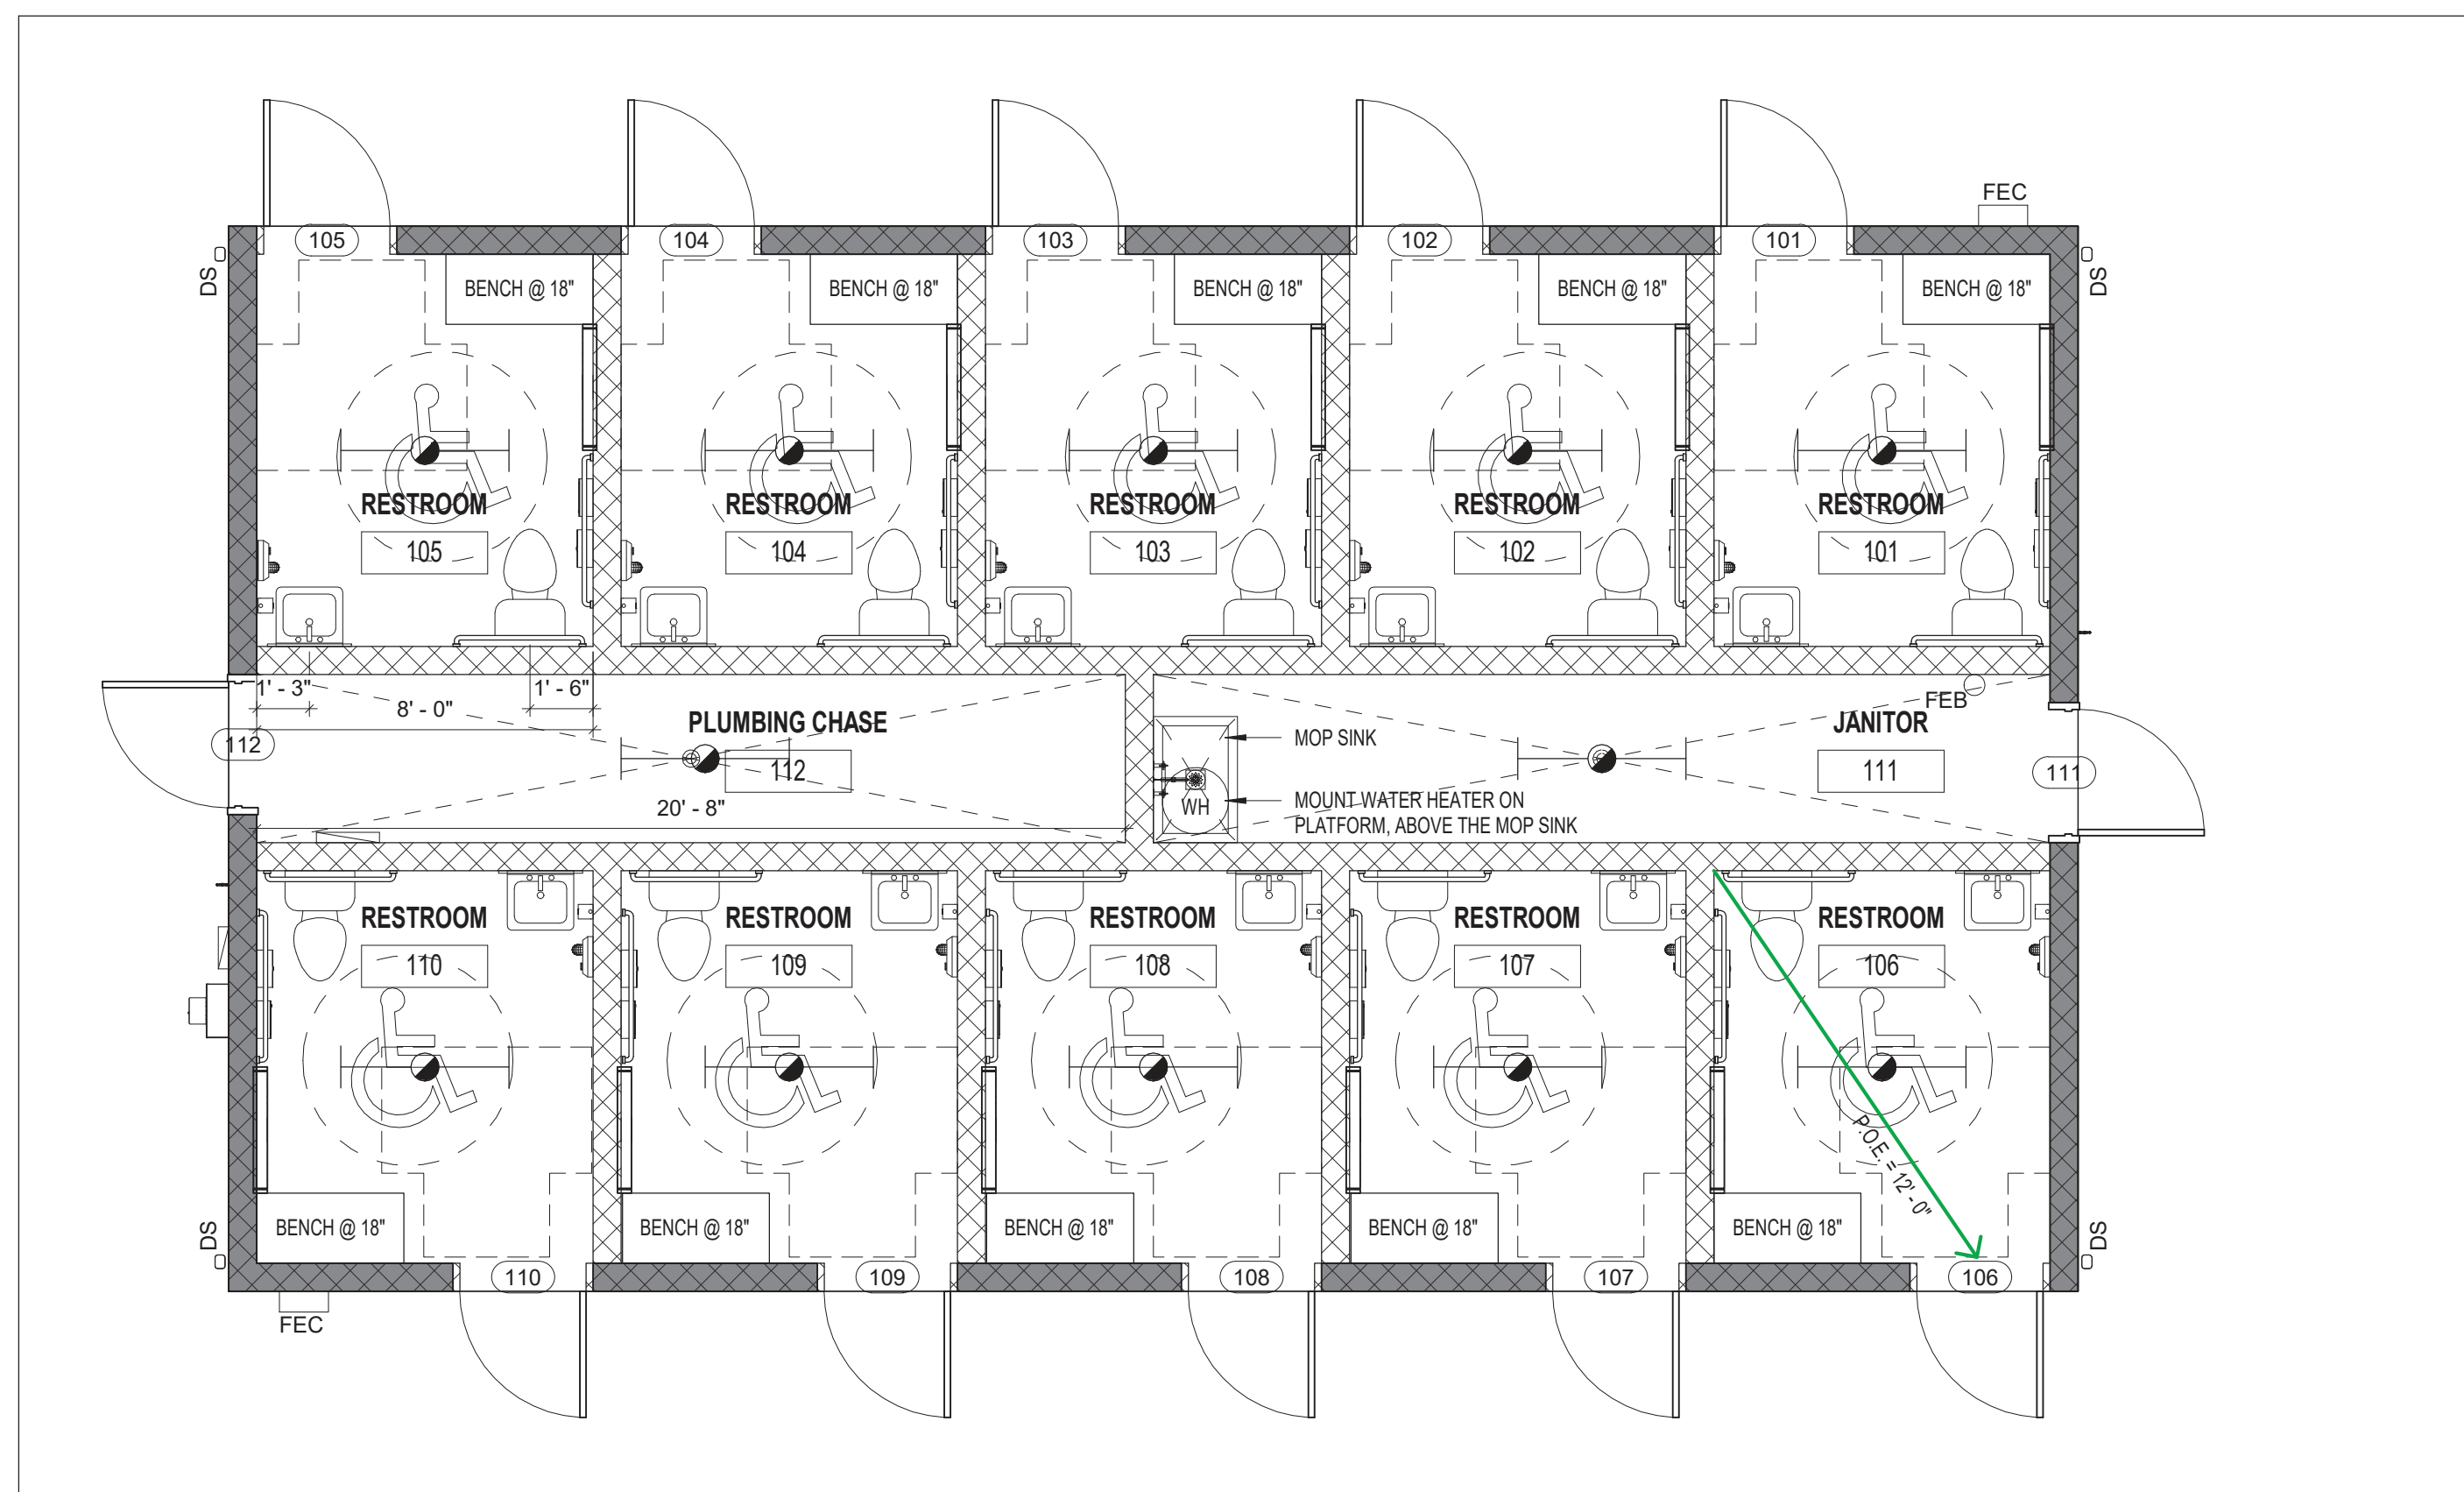




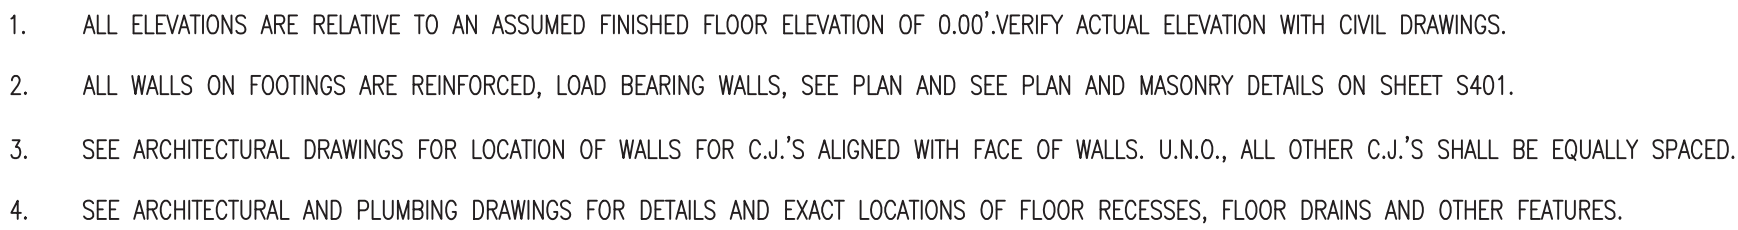


100% CONTRACT DOCUMENTS

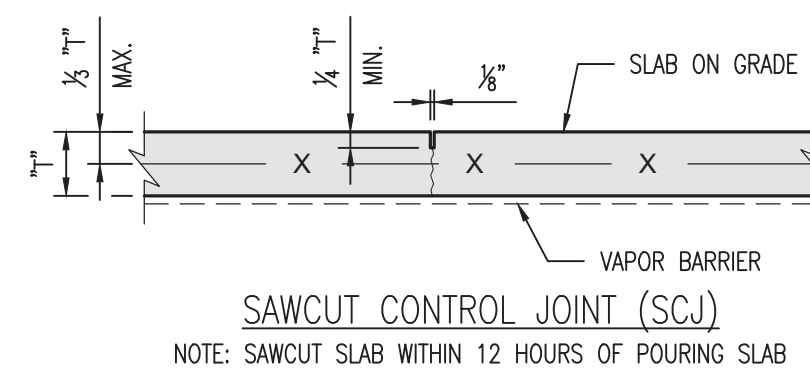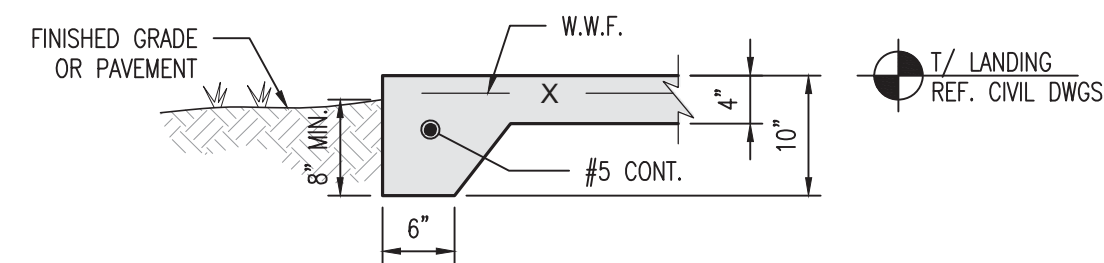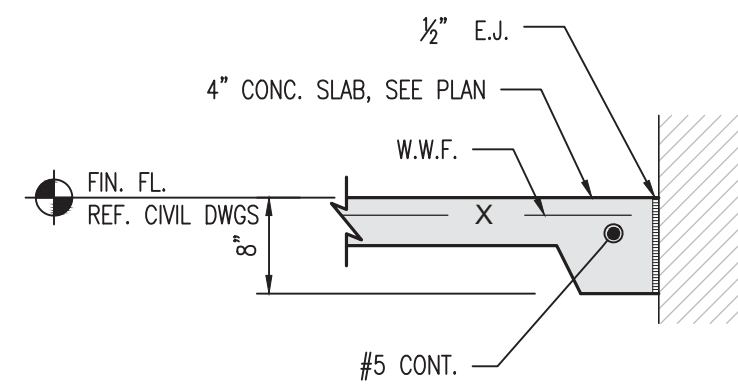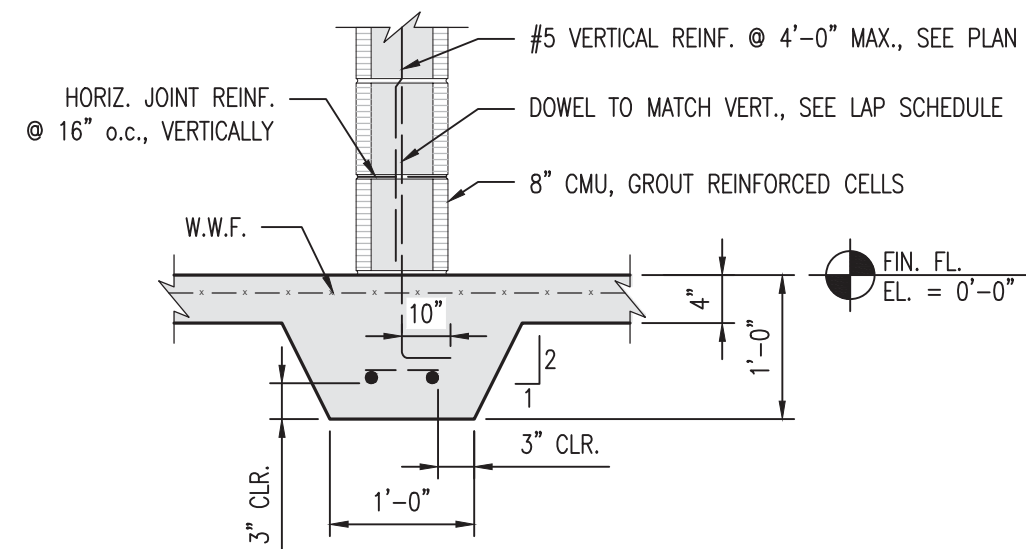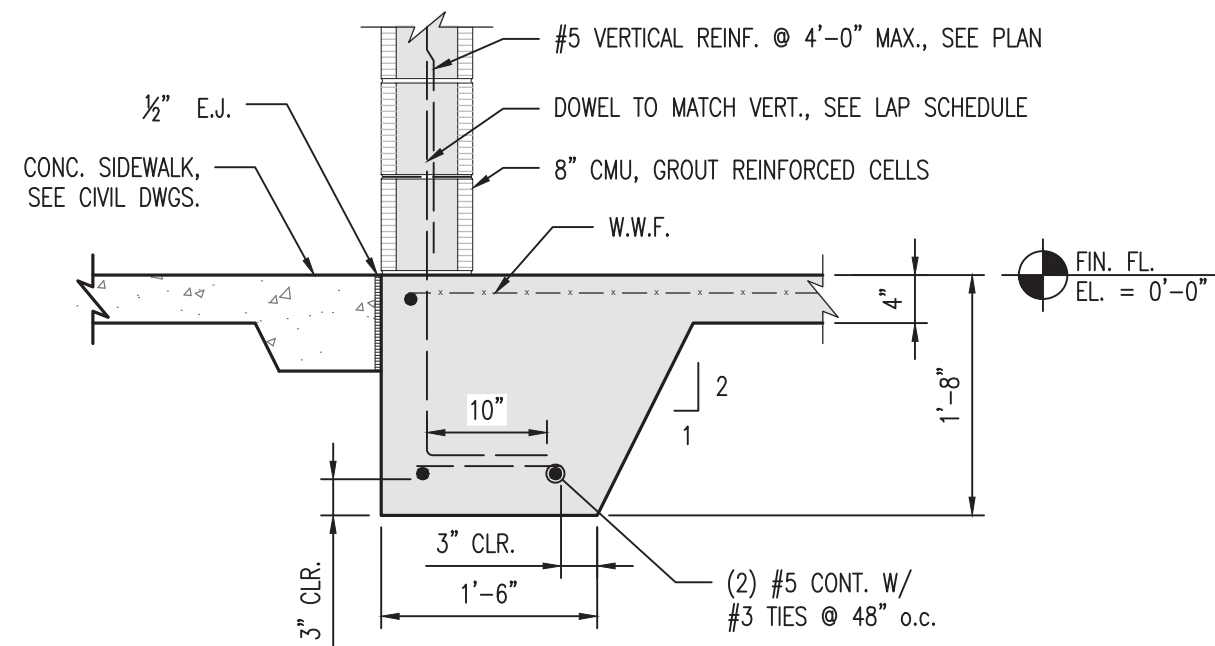


- NOTES:
1. REFER TO ARCHITECTURAL FLOOR PLANS FOR JOINT LAYOUT AT EXPOSED FLOORS, AT ALL OTHER LOCATIONS, LAY OUT JOINTS WITH MAXIMUM SPACING OF 12'-0" ON CENTER AND A MAXIMUM LENGTH TO WIDTH RATIO FOR JOINT SPACING OF 2:1.
 2. RIPS, TEARS, AND HOLES IN VAPOR BARRIERS SHALL BE REPAIRED PRIOR TO PLACING CONCRETE.
 3. ALL SLABS SHALL BE CURED WITH A MOISTURE RETAINING COVER FOR A MINIMUM OF SEVEN DAYS.
 4. ALL JOINTS SHOWN IN PLANS ARE SCHEMATIC. CONTRACTOR SHALL SUBMIT JOINT LOCATION PLAN FOR ARCHITECTURAL APPROVAL.

TYP. SLAB ON GRADE DETAILS
SCALE: 1" = 1'-0"

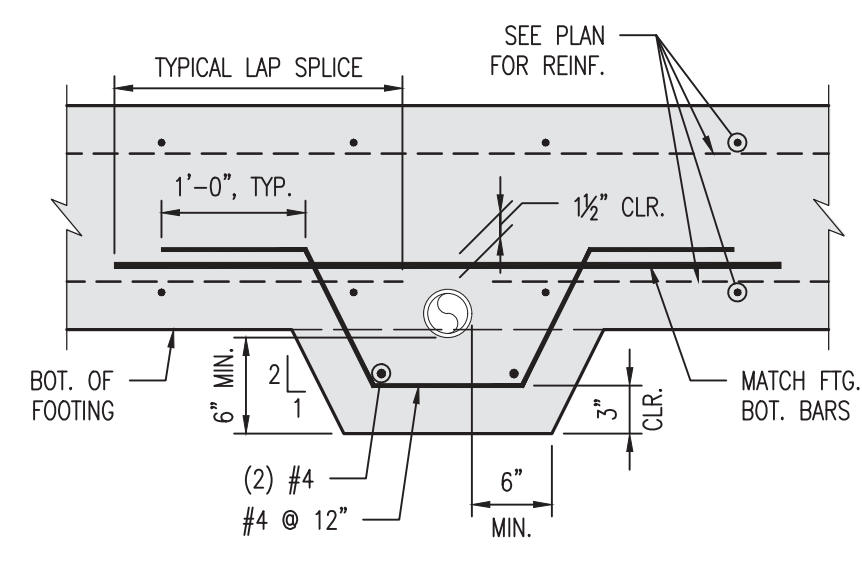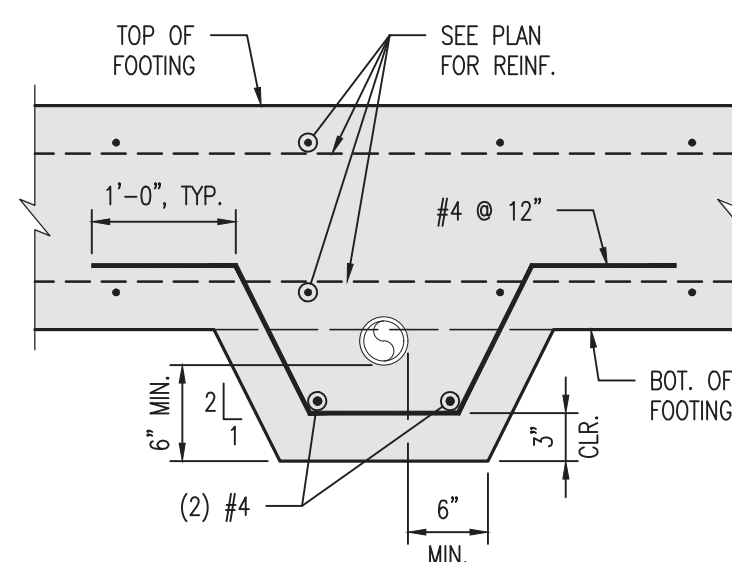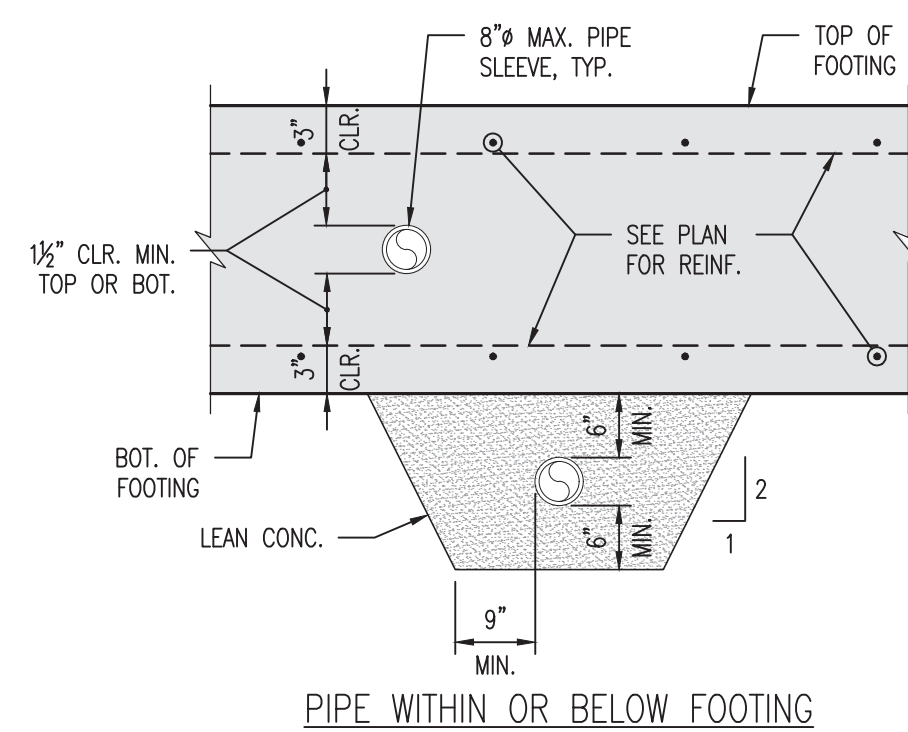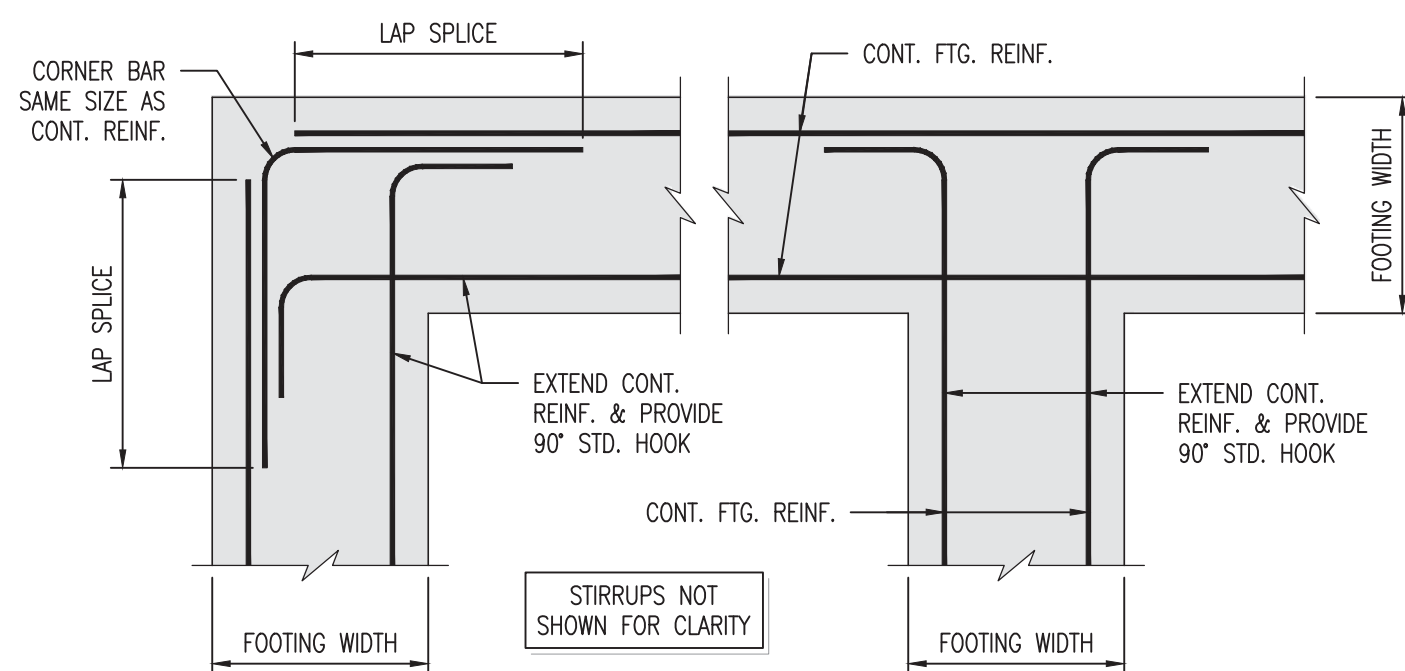


TYP. FTG. PENETRATION DETAIL
SCALE: 1" = 1'-0"

SHEET NO. S301	ICHETUKNEE SPRINGS STATE PARK 12087 SOUTHWEST U.S. 27, FORT WHITE, FL 32038	PROFESSIONAL REGISTRATION PATRICK M. MCKEE FL PE 63122	 PATRICK M. MCKEE, P.E. KEVER MCKEE ENGINEERING FLORIDA PE No. 63122	 KEVER MCKEE ENGINEERING 1624 METROPOLITAN BLVD SUITE A TALLAHASSEE, FLORIDA 32308 p.: 850/727-5367	Department of Environmental Protection Office of Operations <i>Bureau of Design and Construction</i> 3500 Commonwealth Blvd., Tallahassee, FL 32399 (850) 424-2300							
	SHEET TITLE				FOUNDATION DETAILS	DESIGNER: KSUMNER	ISSUE DATE: 28 MARCH 2023	SUBMITAL	REVISION	DATE	REVISION	DATE
PROJECT TITLE	ICHETUKNEE SPRINGS STATE PARK REPLACE RESTROOM	DRAWN BY: KSUMNER	COMP. FILE NO.: 16880	1								
		REVIEWED BY: PMCKEE	STATE PROJECT NO.: 61963C	3								

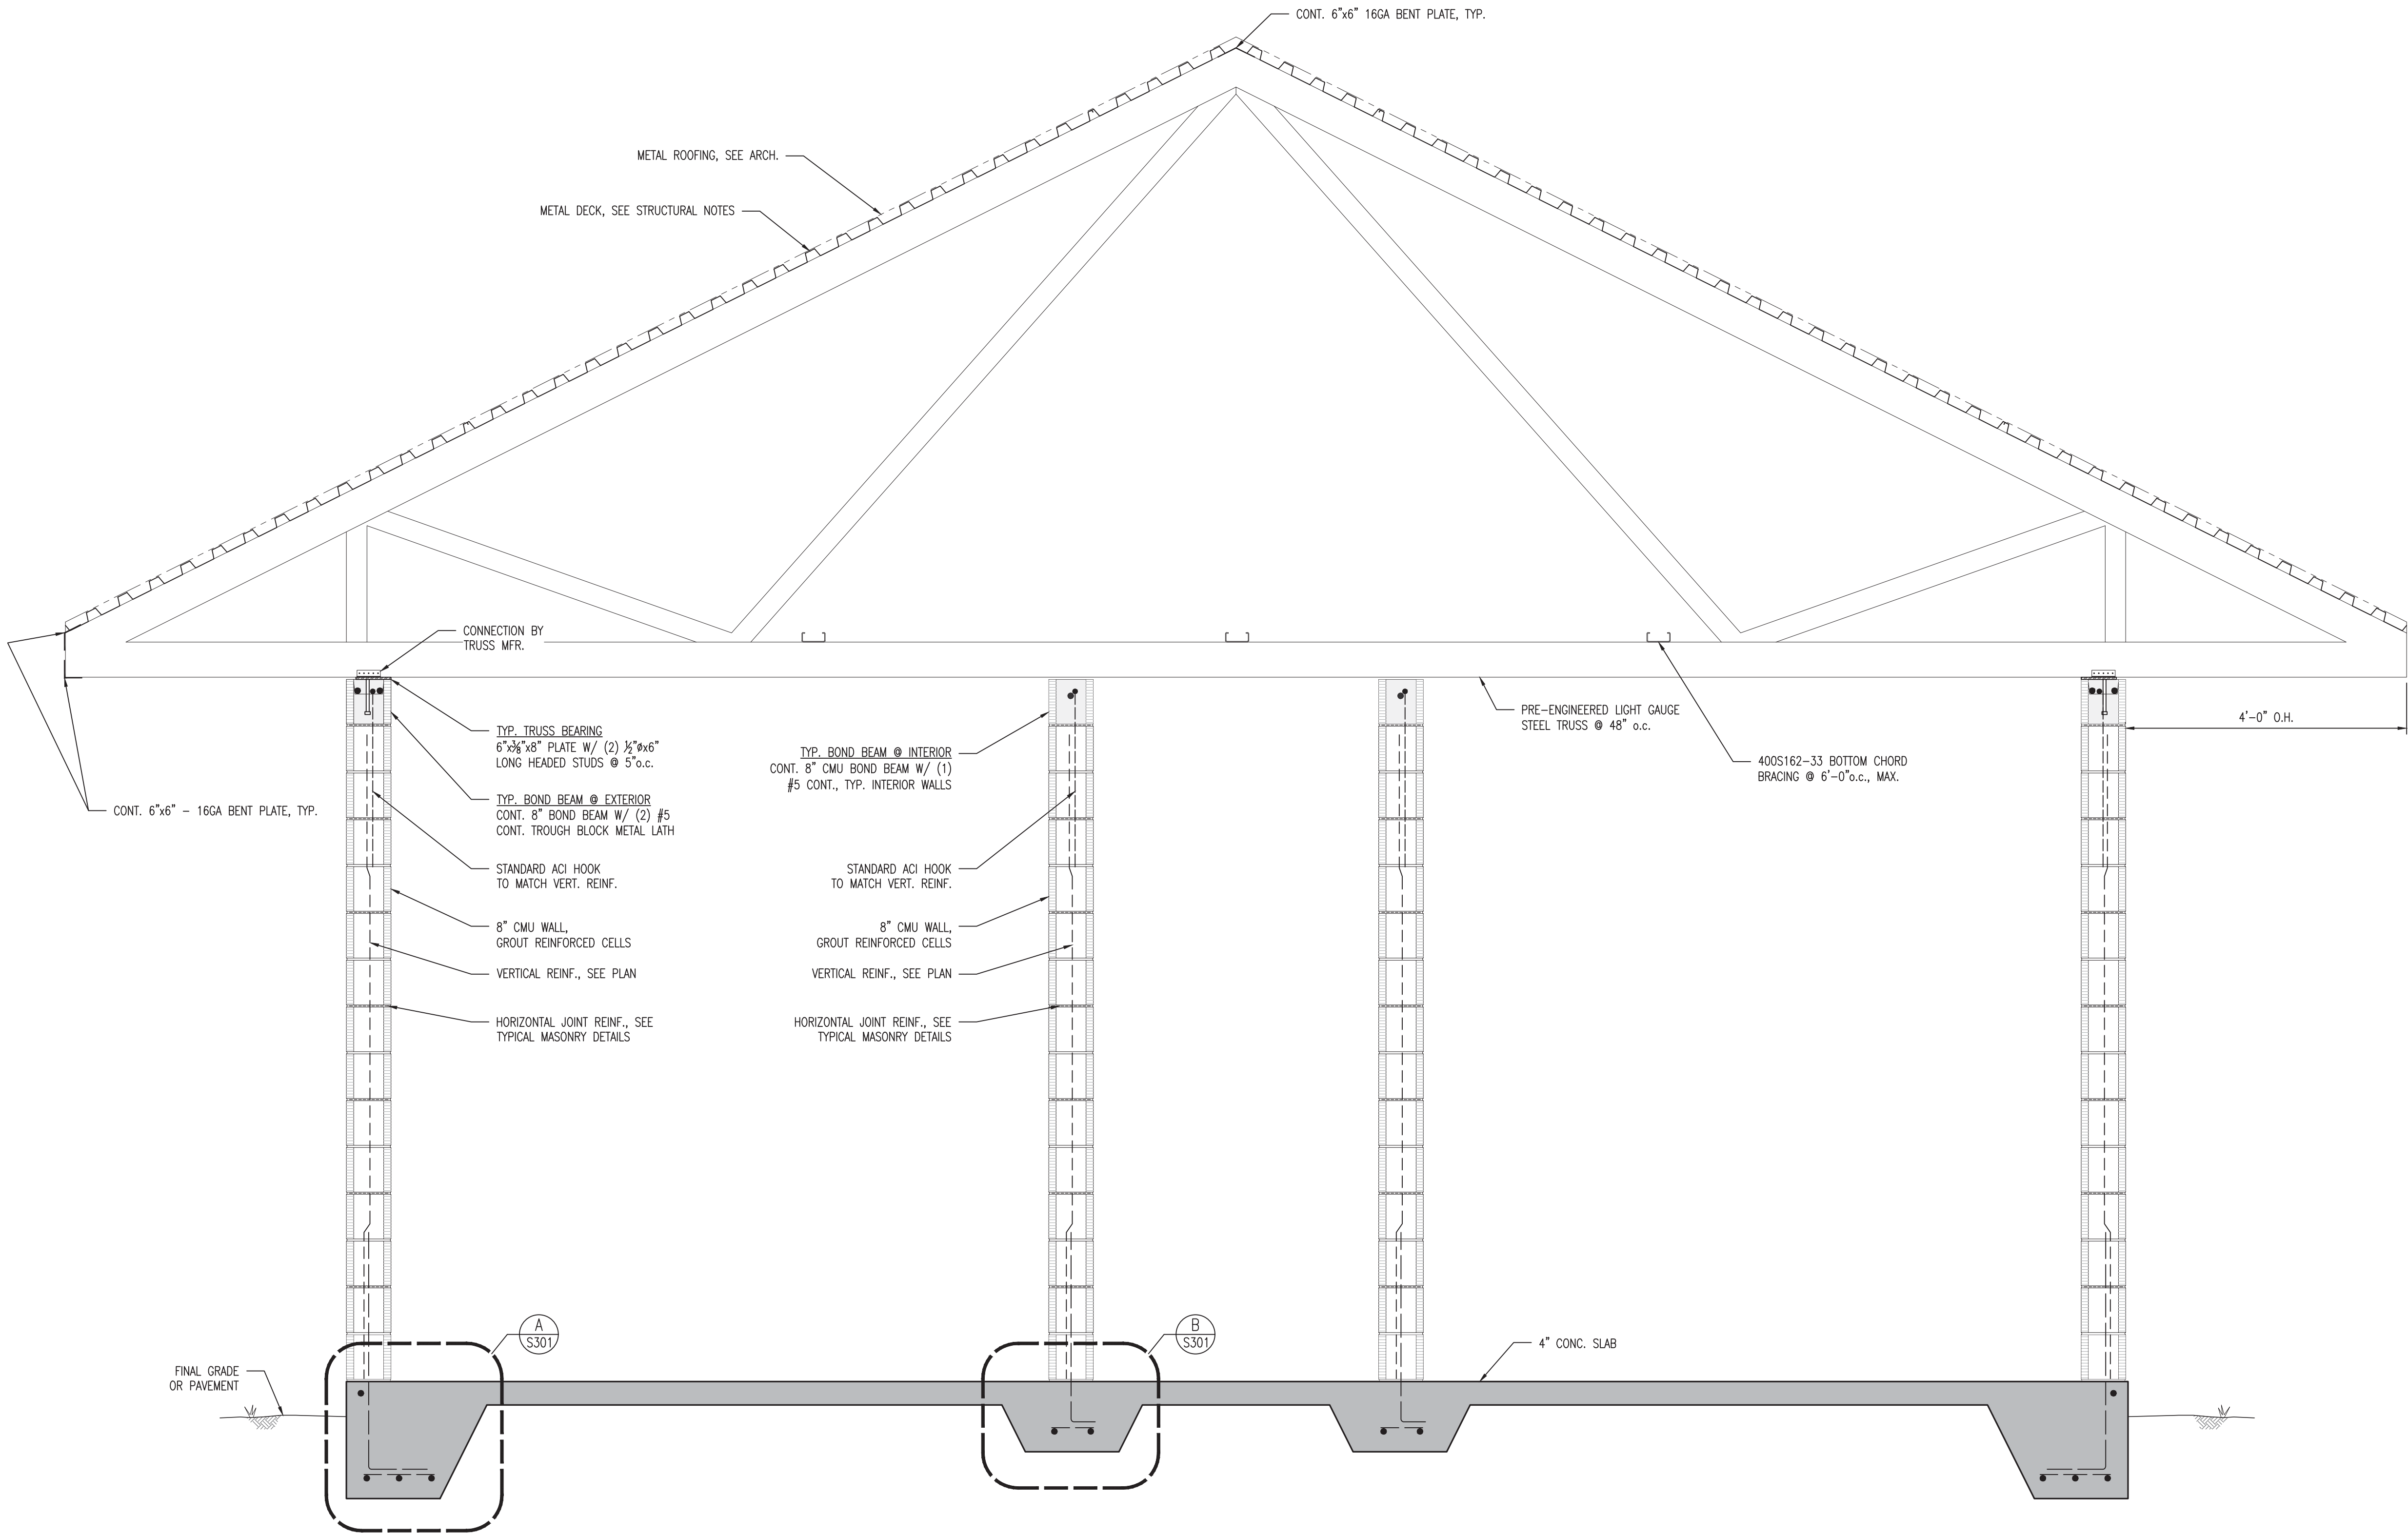

TYPICAL BUILDING SECTION
SCALE: 3/4" = 1'-0"

SHEET NO.		SYMBOL		REVISION		DATE	SYMBOL	REVISION	DATE
S302		1	2	3			3		
		4		5			4		
PROJECT TITLE		ISSUE DATE		COMP. FILE NO.		28 MARCH 2023	STATE PROJECT NO.		6185C
12087 SOUTHWEST U.S. 27, FORT WHITE, FL 32038		DESIGNER:		DRAWN BY:		KSJUNNER	CONSULTANT:		KEVER MCKEE ENGINEERING
TYPICAL BUILDING SECTION		REVIEWED BY:		DATE		PMCKEE	1624 METROPOLITAN BLVD		SUITE A
ICHELUCKNEE SPRINGS STATE PARK		DESIGNER:		DRAWN BY:		KSJUNNER	TALLAHASSEE, FLORIDA 32308		
REPLACE RESTROOM		REVIEWED BY:		DATE		PMCKEE	P: 850.727.5367		
100% CONTRACT DOCUMENTS		PROFESSIONAL REGISTRATION		PATRICK M. MCKEE		FL PE 63122	STATE OF FLORIDA		Professional Engineer License No. 63122
		PATRICK M. MCKEE, P.E.		KEVER MCKEE ENGINEERING		FLORIDA PE No. 63122	Department of Environmental Protection		Office of Operations
							Bureau of Design and Construction		3800 Commonwealth Blvd., Tallahassee, FL 32399 (850) 424-2300

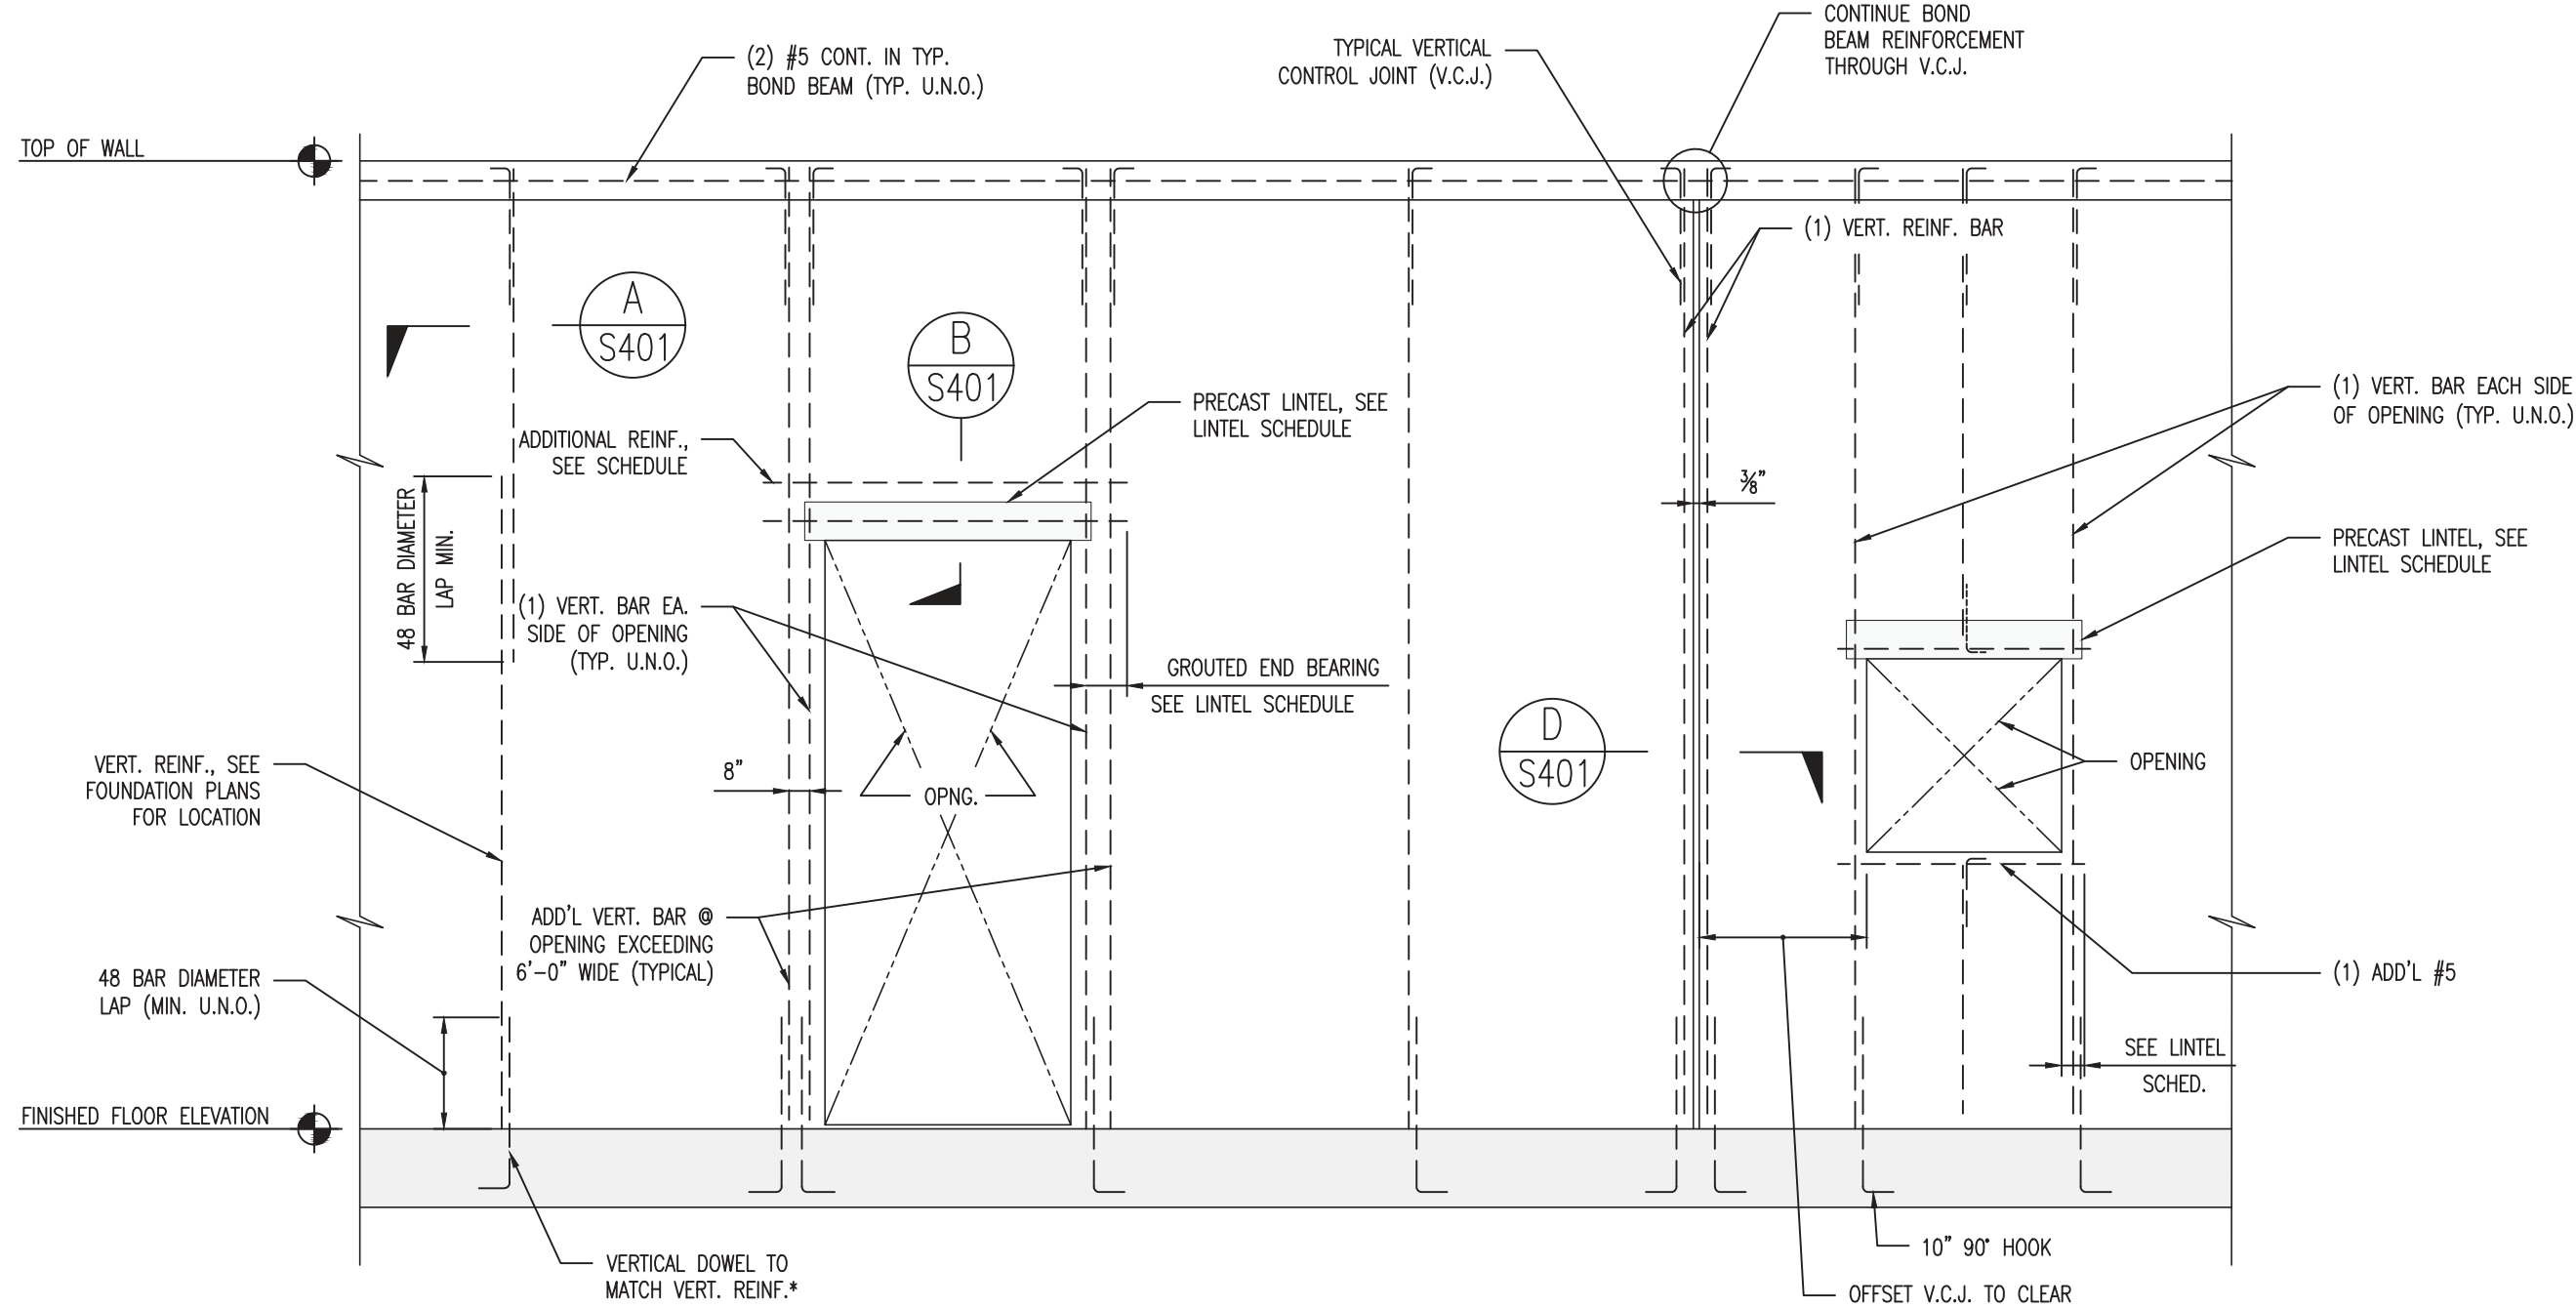


NOTE:
#5 REINFORCEMENT SHOWN IN
ELEVATION. PROVIDE #6 WHERE
INDICATED ON PLAN

TYP. MASONRY WALL REINF. ELEVATION
NO SCALE



LINTEL SCHEDULE (EXCEPT AS INDICATED OTHERWISE ON DRAWINGS)						
CLEAR SPANS	PRECAST LINTEL TYPE	DEPTH	GROUTED END BEARING	BOTTOM BARS	INTERMEDIATE BARS	TOP BARS
UP TO 2'-0" (INCL.)	PRECAST	8"	8" EA. END	GROUT SOLID	-	-
2'-0" TO 3'-8" (INCL.)	PRECAST	8"	8" EA. END	1 #5	-	-
3'-8" TO 6'-0" (INCL.)	PRECAST	16"	8" EA. END	1 #5	-	-
6'-0" TO 8'-0" (INCL.)	PRECAST	16"	16" EA. END	1 #5	-	1 #5

NOTES:


- PRECAST LINTELS SHALL BE AS MANUFACTURED BY CAST-CRETE OR APPROVED EQUIVALENT.
- AT MINIMUM PRECAST LINTELS SHALL HAVE NO LESS THEN 8" BEARING ON JAMB.
- IF FULL BEARING CANNOT BE OBTAINED, PROVIDE ANGLE BEAM SEAT WELDED SOLID TO STEEL COLUMN WITH BEARING LENGTH OF NOT LESS THAN 6" AND END REACTION OF 5 KIPS. WELD REINFORCING STEEL TO STEEL COLUMN.
- TOP REINFORCING TO BE 1/2" CLEAR FROM TOP OF LINTEL BEAM; BOTTOM REINFORCING TO BE 1/2" CLEAR FROM BOTTOM OF LINTEL BEAM.
- REINFORCING STEEL TO HAVE 1/2" CLEARANCE FROM INTERIOR FACE OF VOID.
- UNLESS APPROVED BY THE E.O.R., DO NOT NOTCH OR CUT LINTEL BEAMS FOR DUCTS, PIPES OR OTHER OPENINGS.

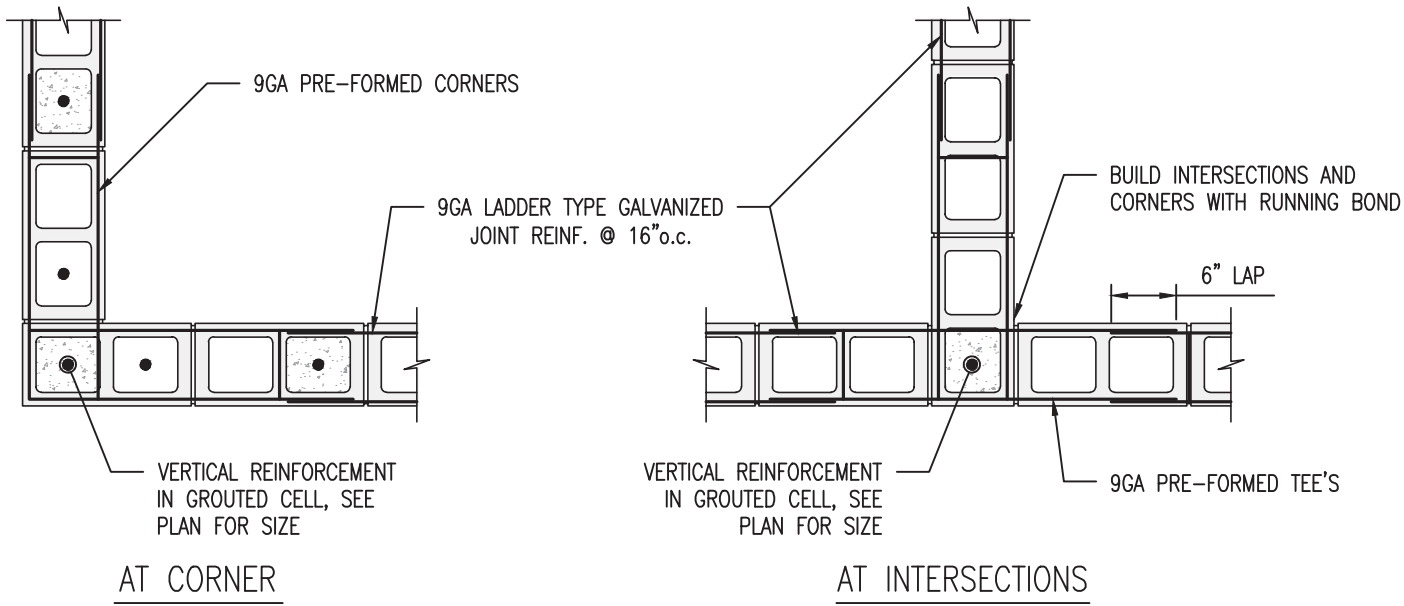


TYPICAL MASONRY WALL REINFORCING DETAILS A
NO SCALE

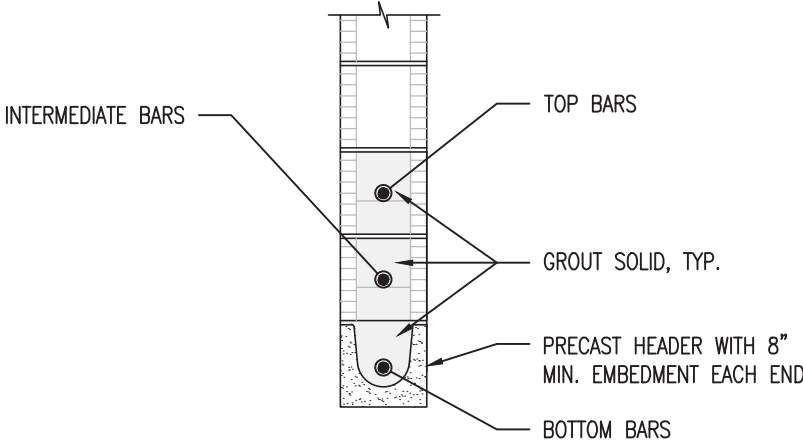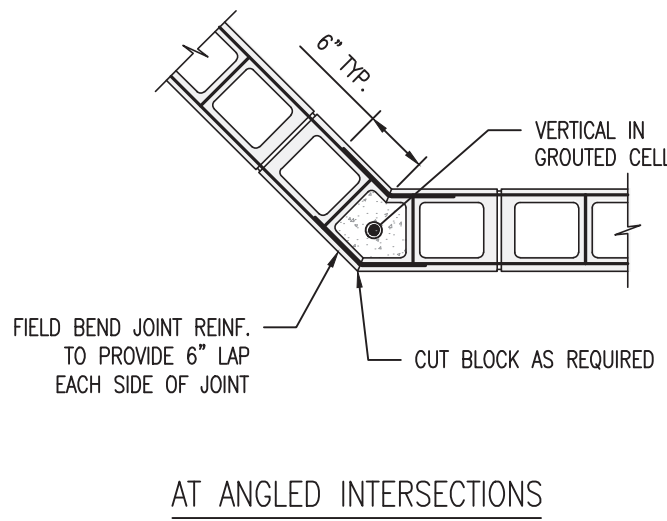


TYPICAL LINTEL DETAIL B
NO SCALE

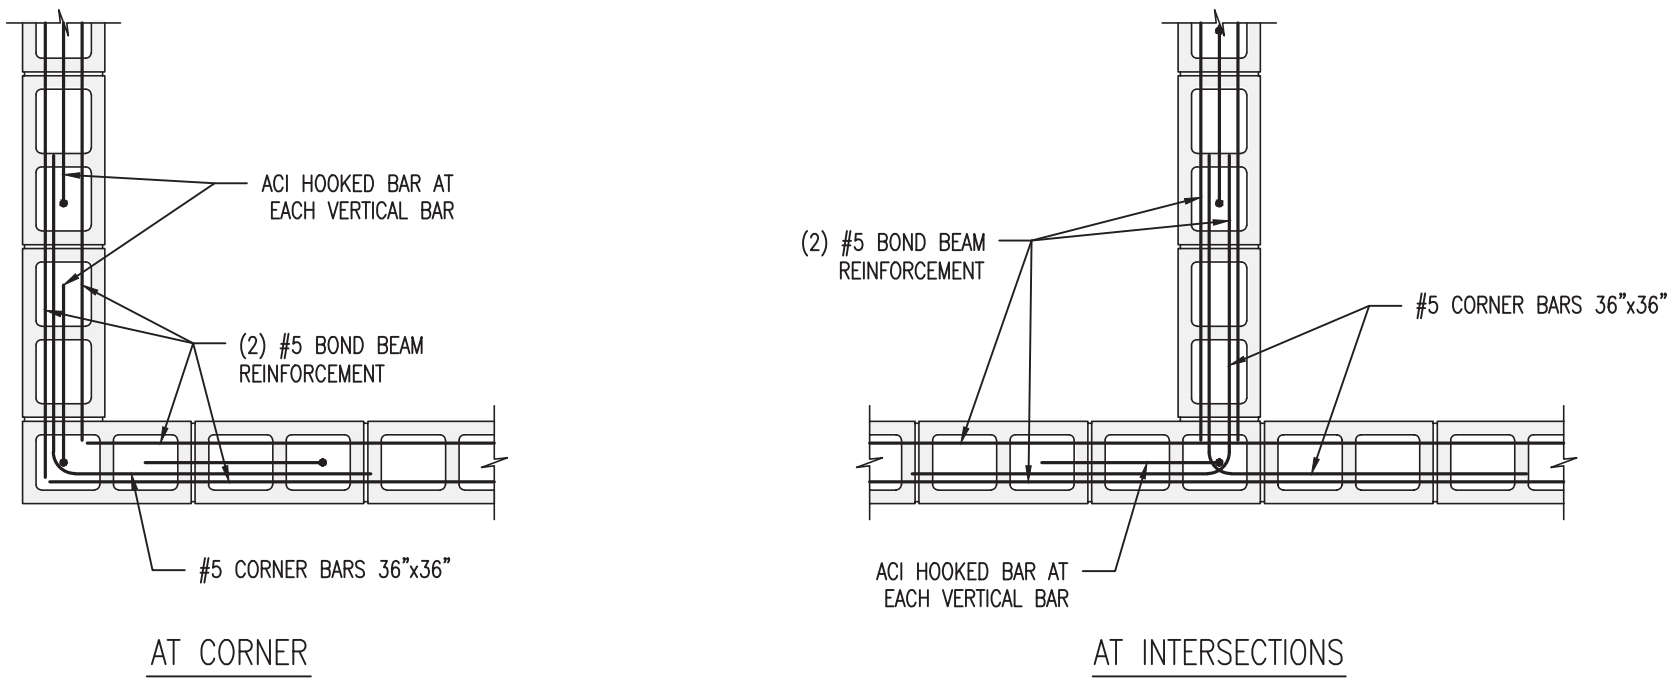

BOND BEAM REINFORCING DETAILS C
NO SCALE

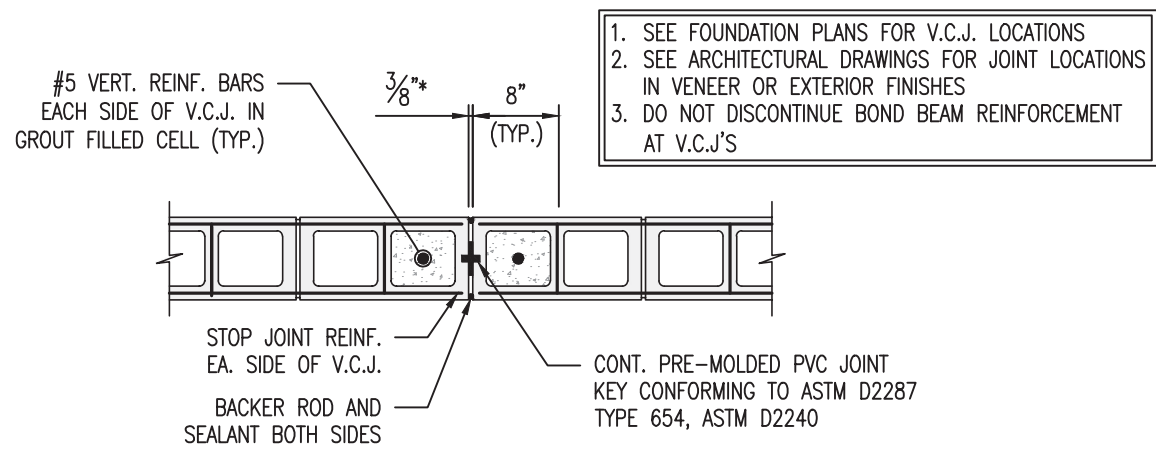

VERTICAL CONTROL JOINT DETAIL D
NO SCALE

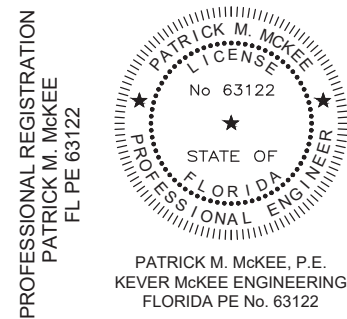

ICHELUCKNEE SPRINGS STATE PARK
12087 SOUTHWEST U.S. 27, FORT WHITE, FL 32038

TYPICAL MASONRY DETAILS

ICHELUCKNEE SPRINGS STATE PARK
REPLACE RESTROOM

SHEET NO.

S401

DESIGNER: KSUMNER
DRAWN BY: KSUMNER
REVIEWED BY: PMCKEE
CONSULTANT: KEVER MCKEE ENGINEERING
1624 METROPOLITAN BLVD
SUITE A
TALLAHASSEE, FLORIDA 32308
P: 850.727.5367


ISSUE DATE: 28 MARCH 2023
COMP. FILE NO.: 18880
STATE PROJECT NO.: 61853C

REVISION
SYMBOL
DATE
SYMBOL
DATE

REVISION
SYMBOL
DATE
SYMBOL
DATE



Department of Environmental Protection
Office of Operations
Bureau of Design and Construction
3800 Commonwealth Blvd., Tallahassee, FL 32399 (850) 424-2300

GENERAL NOTES 1. THE CONTRACTOR IS RESPONSIBLE FOR INSPECTING AND ACCEPTING THE EXISTING CONDITIONS OF THE SITE PRIOR TO BIDDING. 2. ALL DISTURBED AREAS WITHIN THE LIMITS OF RESTORATION SHALL BE REVEGETATED AS SPECIFIED BY THE PARK SERVICE BIOLOGIST. 3. EXISTING UNDERGROUND UTILITIES SHOWN ARE BASED ON THE BEST AVAILABLE INFORMATION. THE CONTRACTOR SHALL ENSURE THAT THE UTILITY SYSTEMS DO NOT CONFLICT WITH THE PROPOSED PROJECT. CONFLICTS SHALL BE REPORTED TO THE PROJECT MANAGER IMMEDIATELY. 4. THE CONTRACTOR IS RESPONSIBLE FOR THE PROTECTION OF ALL UTILITIES. REMOVAL AND/OR RELOCATION OF EXISTING UTILITIES IN CONFLICT WITH THE WORK, CONSTRUCTION OF TEMPORARY UTILITIES IN THE EVENT THAT EXISTING UTILITY SERVICE MUST BE INTERRUPTED AND ANY OTHER CONSTRUCTION RELATED ACTIVITIES THAT MAY AFFECT EXISTING OR PROPOSED UTILITIES, THE INFORMATION SHOWN ON THESE DRAWINGS CONCERNING TYPE AND LOCATION OF UNDERGROUND AND OTHER UTILITIES IS BASED ON INFORMATION PROVIDED BY THE UTILITY OWNERS, AVAILABLE RECORDS, AND SURVEYED FIELD INFORMATION. THE INFORMATION MAY NOT REFLECT ACTUAL CONDITIONS, INCLUDE ALL UTILITIES IN THE AREA, EITHER IN SERVICE OR ABANDONED, OR SHOW THE UTILITIES IN THE CORRECT HORIZONTAL OR VERTICAL LOCATIONS. THE CONTRACTOR WILL MAKE IS OWN DETERMINATION AS TO THE TYPE AND LOCATION OF UTILITIES AS NECESSARY TO ESTABLISH THEIR LOCATIONS AND AVOID DAMAGE. 5. THE CONTRACTOR SHALL BE RESPONSIBLE FOR ESTABLISHING ALL GRADE STAKES, LINES AND LEVELS. 6. THE CONTRACTOR SHALL SOLID SOD ALL DISTURBED AREAS UNLESS OTHERWISE SPECIFIED OR SHOWN. 7. NO SEPARATE PAYMENT WILL BE MADE FOR DEWATERING. THE COSTS FOR DEWATERING ARE INCLUDED IN THE UNIT PRICES FOR CONSTRUCTING THIS PROJECT. 8. ALL AREAS, STREETS, DRIVEWAYS, PARKING LOTS, ETC. DISTURBED BY CONSTRUCTION SHALL BE RESTORED BY THE CONTRACTOR TO THEIR ORIGINAL OR BETTER CONDITION. 9. THE CONTRACTOR WILL HAVE ALL REQUIRED PERMITS IN-HAND PRIOR TO BEGINNING CONSTRUCTION, AND WILL PERFORM ALL WORK IN ACCORDANCE WITH THE REQUIREMENTS OF THE PERMITS OBTAINED BY THE OWNER AND THOSE PERMITS OBTAINED BY THE CONTRACTOR. 10. PRIOR TO COMMENCING CONSTRUCTION, THE CONTRACTOR WILL SUBMIT TO THE OWNER'S PROJECT MANAGER A SCHEDULE OF VALUES, A CONSTRUCTION SCHEDULE, AND A SAFETY PLAN. 11. THE CONSTRUCTION SCHEDULE WILL DESCRIBE IN DETAIL HOW THE CONSTRUCTION IS TO BE PHASED, ESTABLISH START AND FINISH DATES FOR ALL SIGNIFICANT CONSTRUCTION ACTIVITIES, AND IDENTIFY ALL CONTROLLING ITEMS OF WORK. THE SCHEDULE IS TO BE APPROVED BY THE OWNER'S PROJECT MANAGER, AND WILL BE UPDATED ON A MONTHLY BASIS TO REFLECT ACTUAL WORK PROGRESS. PAYMENT FOR PREPARING, UPDATING AND SUBMITTING THE SCHEDULE WILL BE INCLUDED IN THE PAY ITEM FOR MOBILIZATION OR OTHER PAY ITEMS AS APPROPRIATE. 12. THE CONTRACTOR SHALL SUBMIT AN EROSION CONTROL PLAN FOR APPROVAL BY THE OWNER'S PROJECT MANAGER AND WILL ADDRESS THE INSTALLATION AND MAINTENANCE OF ALL TEMPORARY AND PERMANENT SEDIMENT AND EROSION CONTROL DEVICES TO BE USED DURING EACH PHASE OF CONSTRUCTION, INCLUDING TREE REMOVAL, CLEARING AND GRUBBING, EXCAVATION, HAULING OF EXCAVATED MATERIALS, AND PLACEMENT OF EMBANKMENT AND BACKFILL. THE PLAN ALSO WILL DETAIL THE EROSION CONTROL MEASURES TO BE EMPLOYED AT ALL STOCKPILE AND CONSTRUCTION STAGING AREAS AND WILL DEFINE THE MAXIMUM LIMITS OF ALL ACTIVE CONSTRUCTION ZONES. 13. ANY NATIONAL GEODETIC SURVEY MONUMENT WITHIN THE LIMITS OF CONSTRUCTION MUST BE PROTECTED. IF IN DANGER OF DAMAGE, THE CONTRACTOR WILL IMMEDIATELY NOTIFY THE PROJECT MANAGER AND: FDEP, BUREAU OF SURVEY AND MAPPING, MS 105 3900 COMMONWEALTH BLVD. TALLAHASSEE, FLORIDA 32399 (850) 245-2806 (OFFICE) (850) 245-2645 (FAX) 14. PRIOR TO ANY SCHEDULED INTERRUPTION OF UTILITY SERVICE, THE CONTRACTOR WILL COORDINATE SUCH INTERRUPTION WITH THE UTILITY PROVIDER AND WILL PROVIDE A MINIMUM 24-HOUR NOTICE TO THE AFFECTED PARTIES. THE CONTRACTOR WILL NOTIFY THE ELECTRIC UTILITY A MINIMUM OF TWO WEEKS PRIOR TO CONSTRUCTION IN THE VICINITY OF THEIR FACILITIES. 15. NO TRENCHES WILL BE ALLOWED TO REMAIN OPEN OVERNIGHT. 16. THE CONTRACTOR IS RESPONSIBLE FOR THE PROTECTION OF VEGETATION ON AND ADJACENT TO THE PROJECT SITE, AND WILL BE SOLELY LIABLE FOR DAMAGE TO VEGETATION ON PROPERTIES ADJACENT TO CONSTRUCTION WORK ZONES. ALL TREES WITHIN THE LIMITS OF CONSTRUCTION ARE TO BE PROTECTED EXCEPT THOSE TREES IDENTIFIED ON THE PLANS TO BE REMOVED. ALL TREES OUTSIDE THE CONSTRUCTION WORK ZONE ARE TO BE PROTECTED TO THE MAXIMUM EXTENT PRACTICABLE. TREE BARRICADES WILL BE INSTALLED AND MAINTAINED AROUND ALL TREES TO BE PROTECTED AS SHOWN ON THE DRAWINGS OR AS DIRECTED BY THE PROJECT MANAGER. 17. THE CONTRACTOR IS RESPONSIBLE TO PLACE AND MAINTAIN ROADSIDE WARNING SIGNS WHEN WORK IS BEING CONDUCTED IN THE PROPERTY RIGHT OF WAY OR WHEN MACHINERY IS ENTERING AND LEAVING THE PROJECT SITE. 18. THE CONTRACTOR IS RESPONSIBLE FOR DISPOSAL OF EXCAVATED MATERIAL OFF-SITE UNLESS OTHERWISE DIRECTED BY THE PROJECT MANAGER. EROSION CONTROL NOTES: 1. ALL EROSION AND SEDIMENTATION CONTROLS SHALL BE INSTALLED PRIOR TO ANY LAND DISTURBING ACTIVITIES. 2. ALL EROSION AND SEDIMENTATION CONTROLS SHALL BE INSPECTED DAILY AND REPAIRS MADE AS NECESSARY TO ENSURE THE PROPER AND CONTINUED FUNCTION OF THE CONTROL(S). 3. ALL EROSION AND SEDIMENTATION CONTROL SHALL REMAIN IN PLACE UNTIL A PERMANENT VEGETATIVE COVER HAS BEEN ESTABLISHED. 4. UNDER NO CIRCUMSTANCES SHALL SEDIMENTS BE PERMITTED TO EXIT THE PROJECT LIMITS, INCLUDING TRACKING BY VEHICLES ONTO PAVED ROADWAYS. THE CONTRACTOR SHALL MAKE IMMEDIATE REPAIRS OR ENHANCEMENTS TO ANY EROSION CONTROL SYSTEM THAT ALLOWS THE RELEASE OF SEDIMENTS. 01 GENERAL REQUIREMENTS Comply with the requirements of the Agreement between the Department of Environmental Protection and the Contractor for the ICHETUCKNEE SPRINGS STATE PARK. Summary of work: This Work consists of all work necessary to construct Day Use Restroom at Gilchrist Blue Springs State Park as shown on the 100% Construction Documents titled Department of Environmental Protection Day Use Restroom by Barnett Fronczak Barlowe & Shuler Architects. The Work includes, but is not limited to, sitework, site utilities, cast-in-place concrete, masonry walls, light gauge metal trusses, plywood sheathing, standing seam metal roofing, tubular skylights, fiber-cement soffits and trim, aluminum louvers, abuse resistant fiber cement panels, hollow metal doors and frames, finish hardware, toilet partitions, toilet accessories, sealants and caulking, painting, signage, new plumbing fixtures and accessories, exhaust systems, lighting and electrical work. Comply with requirements of applicable product or trade standards, except when more rigid requirements are specified or are required by applicable codes. Substitutions are allowed for all products and materials specified below, unless otherwise noted. Substitutions: Adhere to the substitution requirements of FDEP. The following specifications are general in nature and apply only where applicable, as shown on the Drawings. 02 DEMOLITION AND SITE WORK Protection of Existing: Provide protection for all existing elements in the Project and in the Work Area. Provide dust and debris containment barriers protecting existing areas as needed. Coordinate location and type of protection with Architect and Site Manager. Coordinate access and time of work with the Site Manager. 03 CONCRETE See Structural Drawings	04 MASONRY See Structural Drawings for design loads, foundation notes, design details and general conditions. Echelon Coastal Oldcastle (813) 255-4737 - 325 North Street - Longwood Florida 32750 Exterior Walls: Basis of Design for masonry wall shall be Echelon Masonry Split Face - Standard Split Face Colors. NOTE: All block sides connected to the door and louver jambs, etc.; will be required to have a smooth face solid color. Interior Walls: Basis of Design for masonry wall shall be Echelon Masonry Smooth Face Finish Solid Color - Standard Smooth Face Solid Colors. Submit color samples for selection from manufacturer's product line. Submit product literature, certifications, test reports and full size sample(s) of each color specified. Certifications: Concrete blocks for grinding shall conform to ASTM C90. Colored matching or contrasting mortar is available from manufacturer. Units shall be delivered to the jobsite on wooden pallets. Store pallets on level ground and cover with waterproof covering (e.g., tarpaulins) to protect the blocks from inclement weather. Handle blocks carefully to avoid breakage and damage to the finished surfaces. Protection of Work: Cover walls each day after installation to keep open walls protected and dry. After units are installed they should be protected from damage by other trades performing operations that can stain or damage. Carefully following manufacturer's instructions, use Custom Masonry Cleaner and Burnished Custom Masonry Cleaner by PROSOCO (dilute 1 part to 3 parts clean water). Available from manufacturer. DO NOT POWERWASH. CAUTION! Never use Muriatic Acid solution or any cleaner with an acid base on units. Draw blocks from more than one pallet at a time during installation. All exterior mortar shall include manufacturer approved matching water repellent additive added to each batch in the appropriate dosage rates for mortar type (M, S or N) per manufacturer's instructions. See MFG instructions for hot and cold weather construction practices. Lay units using the best concrete masonry practices. Install only quality units; reject all defective units as defined by ASTM C90. Lay blocks with the faces level, plumb and true to the line strung horizontally at the ground or filled and polished face. Units shall have uniform, 3/8" wide joints both horizontally and vertically on the finished side of the wall. Tool joints neatly after they are finger-hard to make them straight and uniform. Size and place cut pieces appropriately to maintain consistency and bond. Complete masonry construction using procedures and workmanship consistent with the best masonry practices. Cutting: Make all unit cuts, including those for bonding, holes, boxes, etc., with motor-driven masonry saws, using either an abrasive or diamond blade. Cut neatly and locate for best appearance. Lay units with full mortar coverage on head and bed joints taking care not to block cores to be grouted or filled with masonry insulation. Tool all mortar joints when thumbprint hard into a concave configuration. Care should be taken to remove mortar from the face of masonry units before it sets. Tuck-point the joints of scored units for proper appearance. All exterior scored units must be tuck-pointed to prevent water penetration. NO RAKE JOINTS. The faces shall conform to the requirements of ASTM C90 when viewed from a distance of twenty (20) feet at right angles to the wall with normal lighting. Install flashing at locations shown in the plans and in strict accordance with the details and the best masonry flashing practices. Keep walls clean daily during installation using brushes, rags and the burlap squares supplied on the pallets. Do not allow excess mortar lumps or smears to harden on the finished surfaces. Harsh cleaning methods after walls have been erected will mar the surface of the blocks. 05 METALS See Structural Drawings for design loads, foundation notes, design details and general conditions. Pipe and Tube Railings: Provide aluminum pipe and tube railings as shown on the Drawings. Bend members at changes in direction and weld all connections. Finish shall be Class I clear anodic finish. Provide 2 inch square aluminum infill panels with 0.2500 " wire, square weave and weighing 0.6 lbs. Per SF. Basis of Design product shall be McNichols Item No. 3793920041 or comparable product acceptable to FDEP. Contractor is provide shop drawings to architect for approval. 06 WOOD AND PLASTICS Rough Carpentry: Provide all wood roof sheathing, grounds, nailers and blocking. Comply with PS 20 "American Softwood Lumber Standard" and PS 1 "U.S. Product Standard for Construction and Industrial Plywood," dressed S4S, 19% max. moisture content. No. 2 grade or better. Install wood grounds, nailers and blocking where required for attaching of other work. Form to shapes required for true level and line of attached work. Coordinate locations with other work involved. Nails, Wire Brads and staples shall comply with FS FF-N-105 and wood screws shall comply with ASME B18.6.1 Plywood backing panels for electrical panels shall be screwed to supports. Interior Finish Carpentry: Provide Architectural wood benches and solid surface material countertops as shown on the Drawings. Provide finish carpentry that complies with AWI premium grade construction. Provide product data, details and shop drawings consisting of dimensioned plans and elevations, large scale details, attachment devices and other components. Provide samples of solid surfacing materials and lumber products stained to match Architects sample. For countertops, provide homogeneous solid surfacing sheets by Avonite, Formica, or Wilsonart, 3/4" thick bonded to plywood with manufacturer's recommended adhesive. Provide 3/4" solid surfacing backsplashes (Architect to select color). 07 THERMAL AND MOISTURE PROTECTION Building Insulation: Closed-Cell Spray Polyurethane Foam: ASTM C1029, Type II, minimum density of 2.0 lb/cu ft (32kg/cu m) Available Manufacturers: Subject to compliance with requirements, manufacturers offering products that may be incorporated into the Work include, but are not limited to, the following: 1. Icynene (Basis of Design), BASF Corporation, Certain Teed Corporation, Dow Chemical Company or other Architect approved product. 2. Surface-Burning Characteristics: Comply with ASTM E84; testing by a qualified testing agency. Identify products with appropriate markings of applicable testing agency. a. Flame-Spread Index: 25. b. Smoke-Developed Index: 450 or less. 3. Fire Propagation Characteristics: Passes NFPA 285 testing as part of an approved assembly. a. Provide a 6" average thickness (R=38) of foam. Masonry Insulation: Vermiculite loose insulation - Basis of Design: Zonolite Masonry insulation. Weather Barriers: Provide Butyl Rubber, flexible underlayment and flashing under all surfaces of Standing Seam Sheet Metal Roofing panels. Material shall be composite, self adhesive product such as Grace Ice and Water Shield-HT, Polyglass Polystick TU Plus, Tamko TW Metal and Tile Underlayment, Atlas Weathermaster Polyseal, Carlisle WIP 300HT, Dewitt Products Lite N Smooth, Owens Corning Weatherlock, MFM Ultra HT Wind & Water, Mid-States Asphalt Quick Stick HT, Resisto/Soprema Lastobond Shield HT, TARCO Leak Barrier PS200HT, Titanium PSU-30, or other product approved in writing by FDEP. Standing-Seam Metal Roof Panels: Provide standing seam metal roof panels as shown on the Drawings. Provide Vertical Rib, Seamed-Joint metal roof panels formed with vertical ribs at panel edges and a flat pan between ribs; designed for sequential installation by mechanically attaching panels to supports using concealed clips located under one side of the panels, engaging the opposite edge of adjacent panels, and mechanically seaming panels together. Acceptable systems are the Englert Series S2000 and Petersen Snap-Clad system. Provide 0.040 inch thick aluminum sheet with snaplock seams. Panels shall coated with the manufacturers standard fluoropolymer 2-coat system with topcoat containing not less than 70% polyvinylidene fluoride resin by weight, complying with AAMA 2604. Panel coverage shall be 16 inches with a panel height of 1.75 inches. Examine substrates for compliance with requirements of manufacturer. Provide self-adhering underlayment prior to installation of panels. Install metal roof panels, trim and accessories to comply with manufacturer's written installation instructions applicable to products and applications indicated. Fiber-Cement Wood Trim and Soffits: Provide ASTM C 1186, Type A, Grade II, noncombustible fiber board by James Hardie Building Products, Inc. or comparable product acceptable to the Architect. Provide soffit materials not less than 5/16" thick, smooth textured to receive paint. Provide 25 year Special Warranty to repair or replace products that fail in materials or workmanship Provide fiber-cement wood trim and non-vented soffits, accessories, starter strips, edge trim, outside and inside corner strips and other items as manufactured by fiber cement manufacturer for configuration as shown on the Drawings. Provide aluminum flashing at windows and door heads. Provide ribbed bugle-head screws of sufficient length to penetrate a minimum of 1 inch into substrate. Examine substrates for compliance with requirements of manufacturer. Install non-vented soffits, trim and accessories to comply with manufacturer's written installation instructions applicable to products and applications indicated.	Sheet Metal Flashing and Trim: Provide sheet metal flashing and trim to withstand wind loads, structural movement, thermally induced movement and exposure to weather. Fabricate sheet metal flashing and trim to comply with recommendations of SMACNA's "Architectural Sheet Metal Manual" that apply to the design, dimension, metal, and other characteristics of the item indicated. Fabricate cleats and attachment devices from same material as sheet metal component being anchored or from compatible, noncorrosive metal recommended by sheet metal manufacturer. Fabricate all flashing materials from aluminum. Flashing thickness shall be 0.032 inch minimum. Sealants and Caulking: Provide Nonstaining, Silicone sealant, single component for all exterior applications. Joint sealant shall be neutral curing, non-traffic to comply with ASTM C 920, Type S, Grade NS, Class 50. Provide mildew-resistant joint sealants at all joints between plumbing fixtures and adjoining walls, floors and counters and all tile control and expansion joints. Provide Acrylic latex joint sealants at perimeter joints between interior wall surfaces and frames of interior doors and other joint as indicated on the Drawings Mildew-resistant joint sealants shall be Dow Corning 786-M White or comparable product approved by the Architect. Acrylic latex joint sealants shall be Tremco Incorporated Tremflex 834 or comparable product approved by the Architect. Silicone joint sealants shall be Dow Corning 795 or comparable product approved by the Architect. Sealants Below Grade: SONOLASTIC® POLYSULFIDE SEALANT or equal. High-performance electrometric nonsag sealant. Multi-component, high-performance, low-modulus polysulfide sealant. Electrometric properties allow +25% joint movement. Withstands constant water immersion. No degrade under limited chemical exposure. Water Repellent: Sure Klean® Weather Seal Blok-Guard® & Graffiti Control II Water Repellent Specification or equal. A clear-drying, water-based silicone emulsion for weatherproofing concrete block and other porous masonry materials and protecting them from graffiti attacks without altering the natural appearance. Blok-Guard® & Graffiti Control II is appropriate for interior and exterior use. Blok-Guard® & Graffiti Control II is easy to apply with low-pressure spray, brush or roller, and protects exterior walls exposed to normal weathering. Graffiti removal from treated surfaces is fast and easy using Defacer Eraser® Graffiti Wipe. Adhere to mfg technical specifications for application. Test a minimum 4 ft.by 4 ft. area on each type of masonry. Use the manufacturer's application instructions. Let protective treatment test area cure before inspection. Keep test panels available for comparison throughout the protective treatment project. 08 DOORS AND WINDOWS Steel Doors and Frames: Comply with Steel Door Institute "Recommended Specification for Standard Steel Doors and Frames" ANSI A250.8. And ANSI A250.4, Level 3 and Physical Performance Level A (Extra Heavy Duty) Model 1 (Full Flush) for exterior doors. Provide G90 galvanized units in all doors and in areas exposed to moisture. Frames shall be minimum 14 gauge with mitered and welded corners. Provide prime painted finish, manufacturer's standard factory applied coat of rust inhibiting primer complying with ANSI 250.10. Finish Hardware: Provide door hardware for swinging doors as scheduled on the Drawings. Hinges shall be Stanley FBB168 Series, US26D 4-1/2 x 4-1/2. Provide weatherstripping and aluminum thresholds at all exterior doors. 09 FINISHES Gypsum Board Assemblies: Provide abuse resistant interior gypsum wallboard as shown on the Drawings. Interior gypsum wallboard ceiling panels shall be Fiberock Aqua-Tough Abuse Resistant gypsum panels as manufactured by United States Gypsum, 5/8" thickness installed on 3/4" furring channels spaced a maximum 16" on center. Screw attach ceiling panels to metal furring. Joint treatment materials shall comply with ASTM C 475 and shall be setting type sandable compound for taping and all purpose joint compound as recommended by the manufacturer for finishing. Painting: The Scope of Work includes painting all exposed interior and exterior surfaces. Painting includes field painting of exposed bare and covered pipes and ducts, hangers, exposed steel and iron work, and primed metal surfaces of mechanical and electrical equipment. Do not paint prefinished items, concealed surfaces, finished metal surfaces, operating parts and labels Examine substrates, areas and conditions under which painting will be performed for compliance with paint application requirements. Clean and prepare surfaces to be painted according to manufacturer's written instructions for each particular substrate condition. Provide barrier coats over incompatible primers or remove and reprime. Provide block fillers, primers, undercoats and finish-coat materials that are compatible with one another and the substrates indicated under conditions of service and application, as demonstrated by manufacturer based on testing and field experience. Apply paint according to manufacturer's written instructions. Use applicators and techniques best suited for substrate and type of material being applied. Provide the following finish systems. Paint materials shall be best quality products by Benjamin Moore, or FDEP approved equal: Gypsum fiber ceiling panels: Provide 2 coats latex egg shell latex enamel over a primer. Ferrous metal (interior and exterior): Provide 2 coats full Alkyd-Enamel finish over an enamel undercoater and a primer. Exterior Wood and Fiber Cement Soffits: Provide 2 coats Full-Gloss, Alkyd-Enamel finish over Exterior Alkyd Wood Primer. Provide Samples, and Color selection palette, for all Finish Materials. 10 SPECIALTIES Louvers and Vents: Provide aluminum wall and door louvers as shown on the Drawings. Wall louvers shall be fixed-blade louvers with extruded aluminum frames and blades, 6" deep with a frame and blade thickness not less than 0.081 inch. Provide aluminum louver insect screens on inside face of louver. Toilet Partitions: Provide solid polymer toilet partitions and privacy screens as delineated on the Drawing. Acceptable manufacturer's are Ampco, Santana or comparable product approved by the Architect. Pilasters shall be floor and ceiling attached. Provide integral hinges from door and pilaster material with exposed metal parts on interior of stall. Provide combination coat hook, bumper. Provide outswinging doors with second door pull and door stop. Pilaster sleeves shall be one piece molded HPDE secured to pilasters. Wall brackets shall be extruded PVC fastened to pilasters and brackets with tamper proof fasteners. Toilet Accessories: Provide toilet accessories as delineated on the Drawings. Prior to ordering of accessories, verify with Owner Product designations and operation. Coordinate accessory locations with other Work to prevent interference with clearances required for access by disabled persons, proper installation, adjustment, operation, cleaning and servicing of accessories. Mirrors shall be warranted for a minimum of 15 years from date of Substantial Completion. Install accessories according to manufacturer's written instructions, using fasteners appropriate to substrate indicated and recommended by unit manufacturer. Install units lever, plumb, and firmly anchored in locations and at heights indicated. Fire Extinguishers: Provide 5 lb. unit with 3A40BC rating standard. Provide one fire extinguisher in locations shown on the Drawings.	ISSUE DATE: 28 MARCH 2023 COMP. FILE NO.: 18880 STATE PROJECT NO.: 61983C CONSULTANT: BFBS ARCHITECTS 2074 CENTRE POINTE BLVD SUITE 200 TALLAHASSEE, FLORIDA 32308 P: 850.224-6301 DESIGNER: DSHULER DRAWN BY: JHIGHTOWER REVIEWED BY: DSHULER PROFESSIONAL REGISTRATION RAY DOUGLAS SHULER FL AR 90089 STATE OF FLORIDA RAY DOUGLAS SHULER ARCHITECT REGISTERED ICHETUCKNEE SPRINGS STATE PARK 12087 SOUTHWEST U.S. 27, FORT WHITE, FL 32038 ARCHITECTURAL SPECIFICATIONS ICHETUCKNEE SPRINGS STATE PARK REPLACE RESTROOM SHEET NO. A100 Department of Environmental Protection Office of Operations Bureau of Design and Construction 3900 Commonwealth Blvd., Tallahassee, FL 32399 (850) 424-2300
--	---	---	--

 


TOILET AND BATH ACCESSORIES ARE FROM "A AND J WASHROOM ACCESSORIES" (845-562-3332) TO INDICATE TYPE, MATERIAL, AND QUALITY OF ACCESSORY, UNLESS OTHERWISE NOTED. OTHER MANUFACTURERS ARE ACCEPTABLE IF EQUAL AND APPROVED.

 *Department of Environmental Protection
Office of Operations
Bureau of Design and Construction*

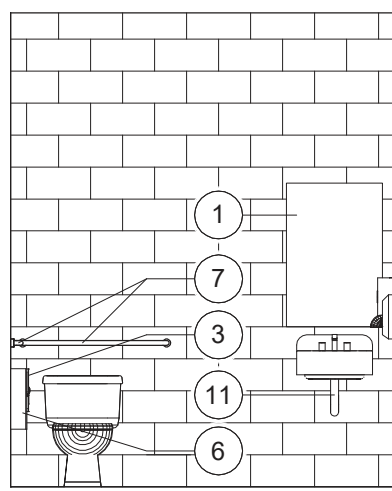


3	RESTROOM ELEV. - TYP.
A102	1/4" = 1'-0"

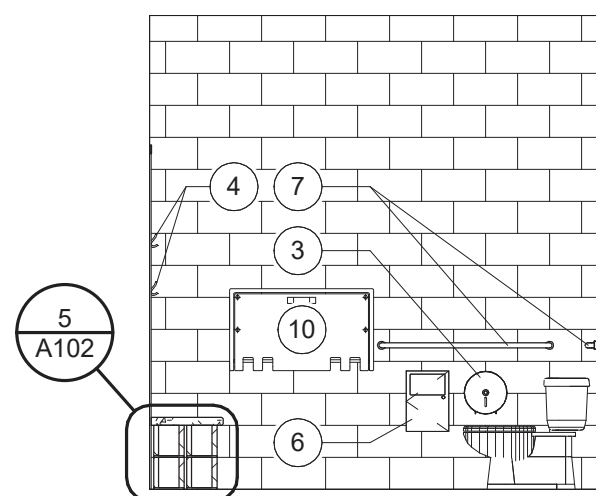


1	RESTROOM BUILDING - PLUMBING DIMENSIONS PLAN
A102	1/4" = 1'-0"

PROFESSIONAL REGISTRATION RAY DOUGLAS SHULER FLA# 90689	DESIGNER: DSHULER	ISSUE DATE: 28 MARCH 2019
	DRAWN BY: JHIGHTOWER	COMP. FILE No.: 19880
	REVIEWED BY: DSHULER	STATE PROJECT No.: 61363C


100% CONTRACT DOCUMENTS

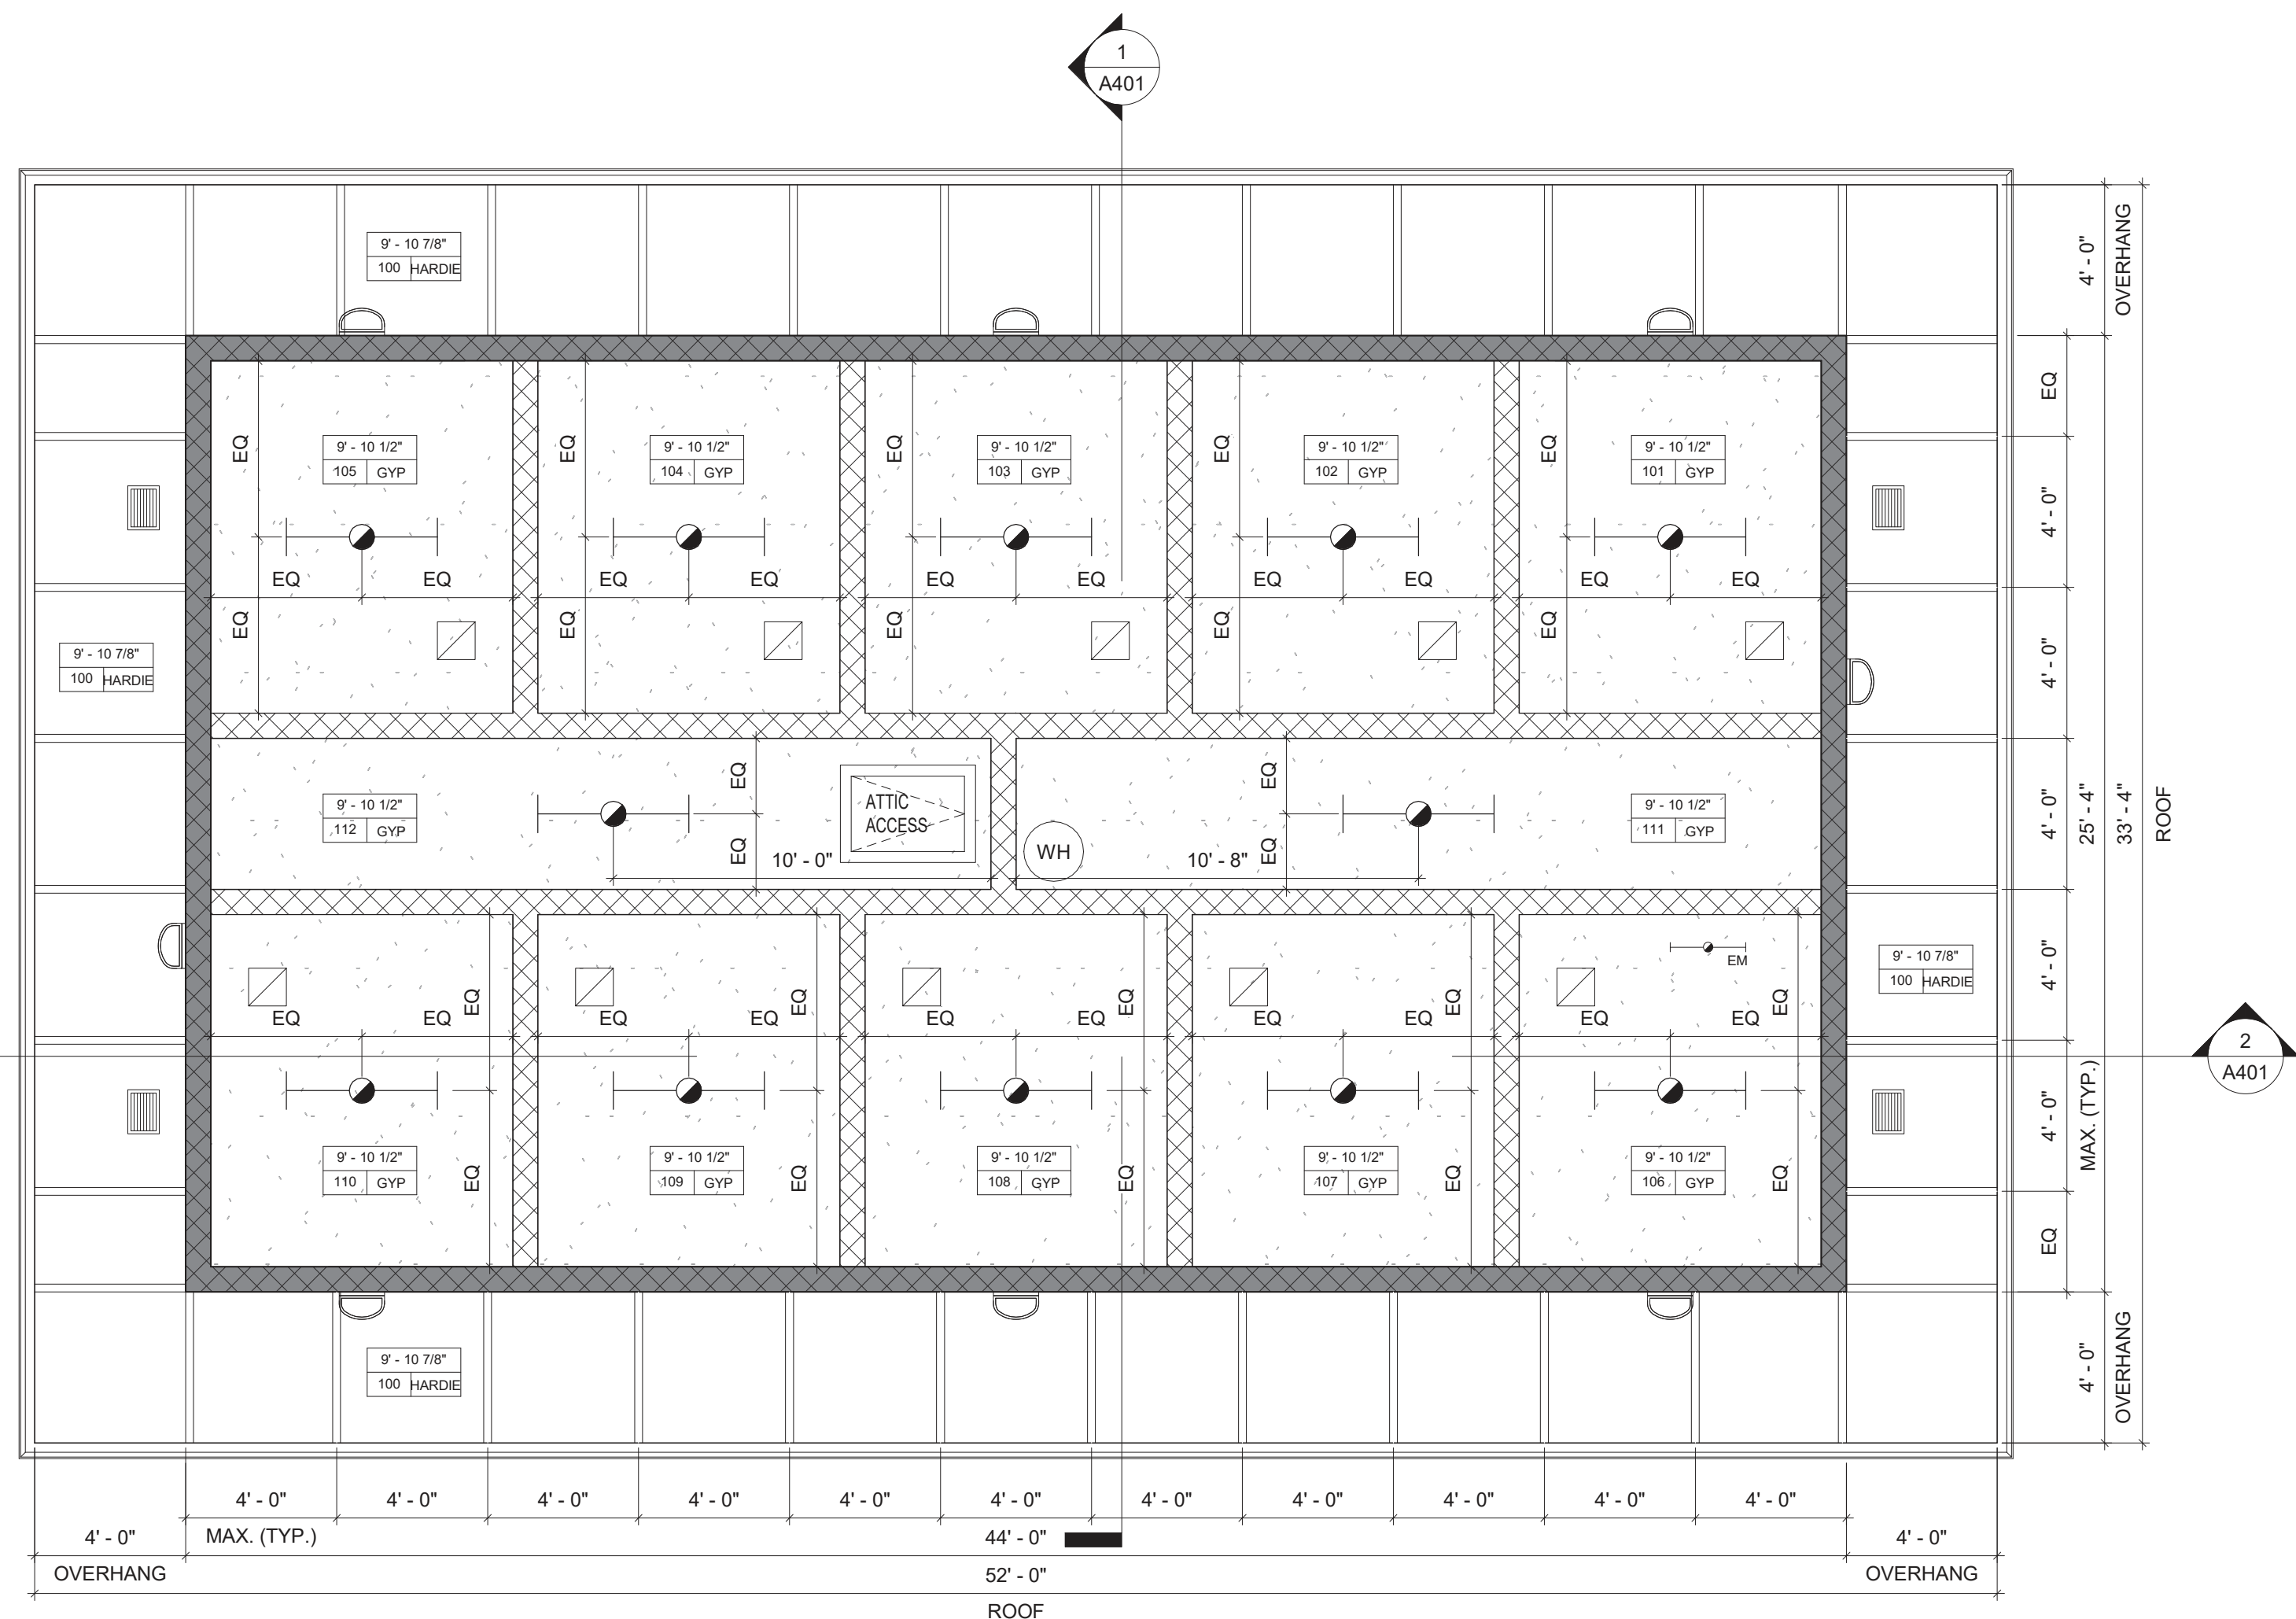

ROOM FINISH SCHEDULE							FINISH SAMPLES SHALL BE PROVIDED TO THE ARCHITECT FOR APPROVAL		
ROOM NO	ROOM NAME	FLOOR	WALLS				CEILING		NOTES
			N	S	E	W	MATERIAL	HEIGHT	
100	COVERED AREA	BROOM FINISHED CONCRETE	-	-	-	-	HARDIE PANEL	SEE A201	SLOPE FLOOR AWAY FROM BUILDING
101	RESTROOM	EPOXY PAINT	PAINT	PAINT	PAINT	PAINT	PAINTED AQUA-TOUGH BOARD	SEE A201	SLOPE FLOOR TO DRAIN
102	RESTROOM	EPOXY PAINT	PAINT	PAINT	PAINT	PAINT	PAINTED AQUA-TOUGH BOARD	SEE A201	SLOPE FLOOR TO DRAIN
103	RESTROOM	EPOXY PAINT	PAINT	PAINT	PAINT	PAINT	PAINTED AQUA-TOUGH BOARD	SEE A201	SLOPE FLOOR TO DRAIN
104	RESTROOM	EPOXY PAINT	PAINT	PAINT	PAINT	PAINT	PAINTED AQUA-TOUGH BOARD	SEE A201	SLOPE FLOOR TO DRAIN
105	RESTROOM	EPOXY PAINT	PAINT	PAINT	PAINT	PAINT	PAINTED AQUA-TOUGH BOARD	SEE A201	SLOPE FLOOR TO DRAIN
106	RESTROOM	EPOXY PAINT	PAINT	PAINT	PAINT	PAINT	PAINTED AQUA-TOUGH BOARD	SEE A201	SLOPE FLOOR TO DRAIN
107	RESTROOM	EPOXY PAINT	PAINT	PAINT	PAINT	PAINT	PAINTED AQUA-TOUGH BOARD	SEE A201	SLOPE FLOOR TO DRAIN
108	RESTROOM	EPOXY PAINT	PAINT	PAINT	PAINT	PAINT	PAINTED AQUA-TOUGH BOARD	SEE A201	SLOPE FLOOR TO DRAIN
109	RESTROOM	EPOXY PAINT	PAINT	PAINT	PAINT	PAINT	PAINTED AQUA-TOUGH BOARD	SEE A201	SLOPE FLOOR TO DRAIN
110	RESTROOM	EPOXY PAINT	PAINT	PAINT	PAINT	PAINT	PAINTED AQUA-TOUGH BOARD	SEE A201	SLOPE FLOOR TO DRAIN
111	JANITOR	EPOXY PAINT	PAINT	PAINT	PAINT	PAINT	PAINTED AQUA-TOUGH BOARD	SEE A201	SLOPE FLOOR TO DRAIN
112	PLUMBING CHASE	EPOXY PAINT	PAINT	PAINT	PAINT	PAINT	PAINTED AQUA-TOUGH BOARD	SEE A201	SLOPE FLOOR TO DRAIN

 RCP LEGEND	
 CEILING HEIGHT CEILING MATERIAL ROOM NUMBER	 NEW CMU WALL PARTITION - SMOOTH FACE EA. SIDE  NEW CMU WALL PARTITION - SPLIT FACE EXTERIOR SIDE
CEILING FINISHES  AQUATOUGH CEILING ON 7/8" HAT HAT CHANNEL @ 24" O.C. - SEE RCP FOR CEILING HEIGHTS  CEMENTITIOUS BOARD (CMT.BD.) SOFFIT W/ 2" BATTENS ON 7/8" HAT HAT CHANNEL @ 24" O.C. - SEE RCP FOR CEILING HEIGHTS	 4'-0" LED LINEAR FIXTURE W/ BATTERY BACK UP  WALL MOUNTED LIGHT

A201	SHEET NO.	ICHTUCKNEE SPRINGS STATE PARK 12087 SOUTHWEST U.S. 27, FORT WHITE, FL 32038							
	SHEET TITLE	RESTROOM BUILDING - REFLECTED CEILING PLAN							
	PROJECT TITLE	ICHTUCKNEE SPRINGS STATE PARK REPLACE RESTROOM							
	PROFESSIONAL REGISTRATION RAY DONALD SHULER FLS 96862		DESIGNER: DSHULER		ISSUE DATE: 28 MARCH 2023		SYMBOL		REVISION
	DRAWN BY: SHULER		COMP. FILE No.: 18960				SYMBOL		DATE
	REVIEWED BY: DSHULER		STATE PROJECT No.: 61383C				SYMBOL		DATE
 BARNETT PRONKAR REGISTERED ARCHITECT BLOWMAN & SHULER CONSULTANT									
Department of Environmental Protection Office of Operations <i>Bureau of Design and Construction</i> 3800 Commonwealth Blvd., Tallahassee, FL 32399 (850) 424-2300									

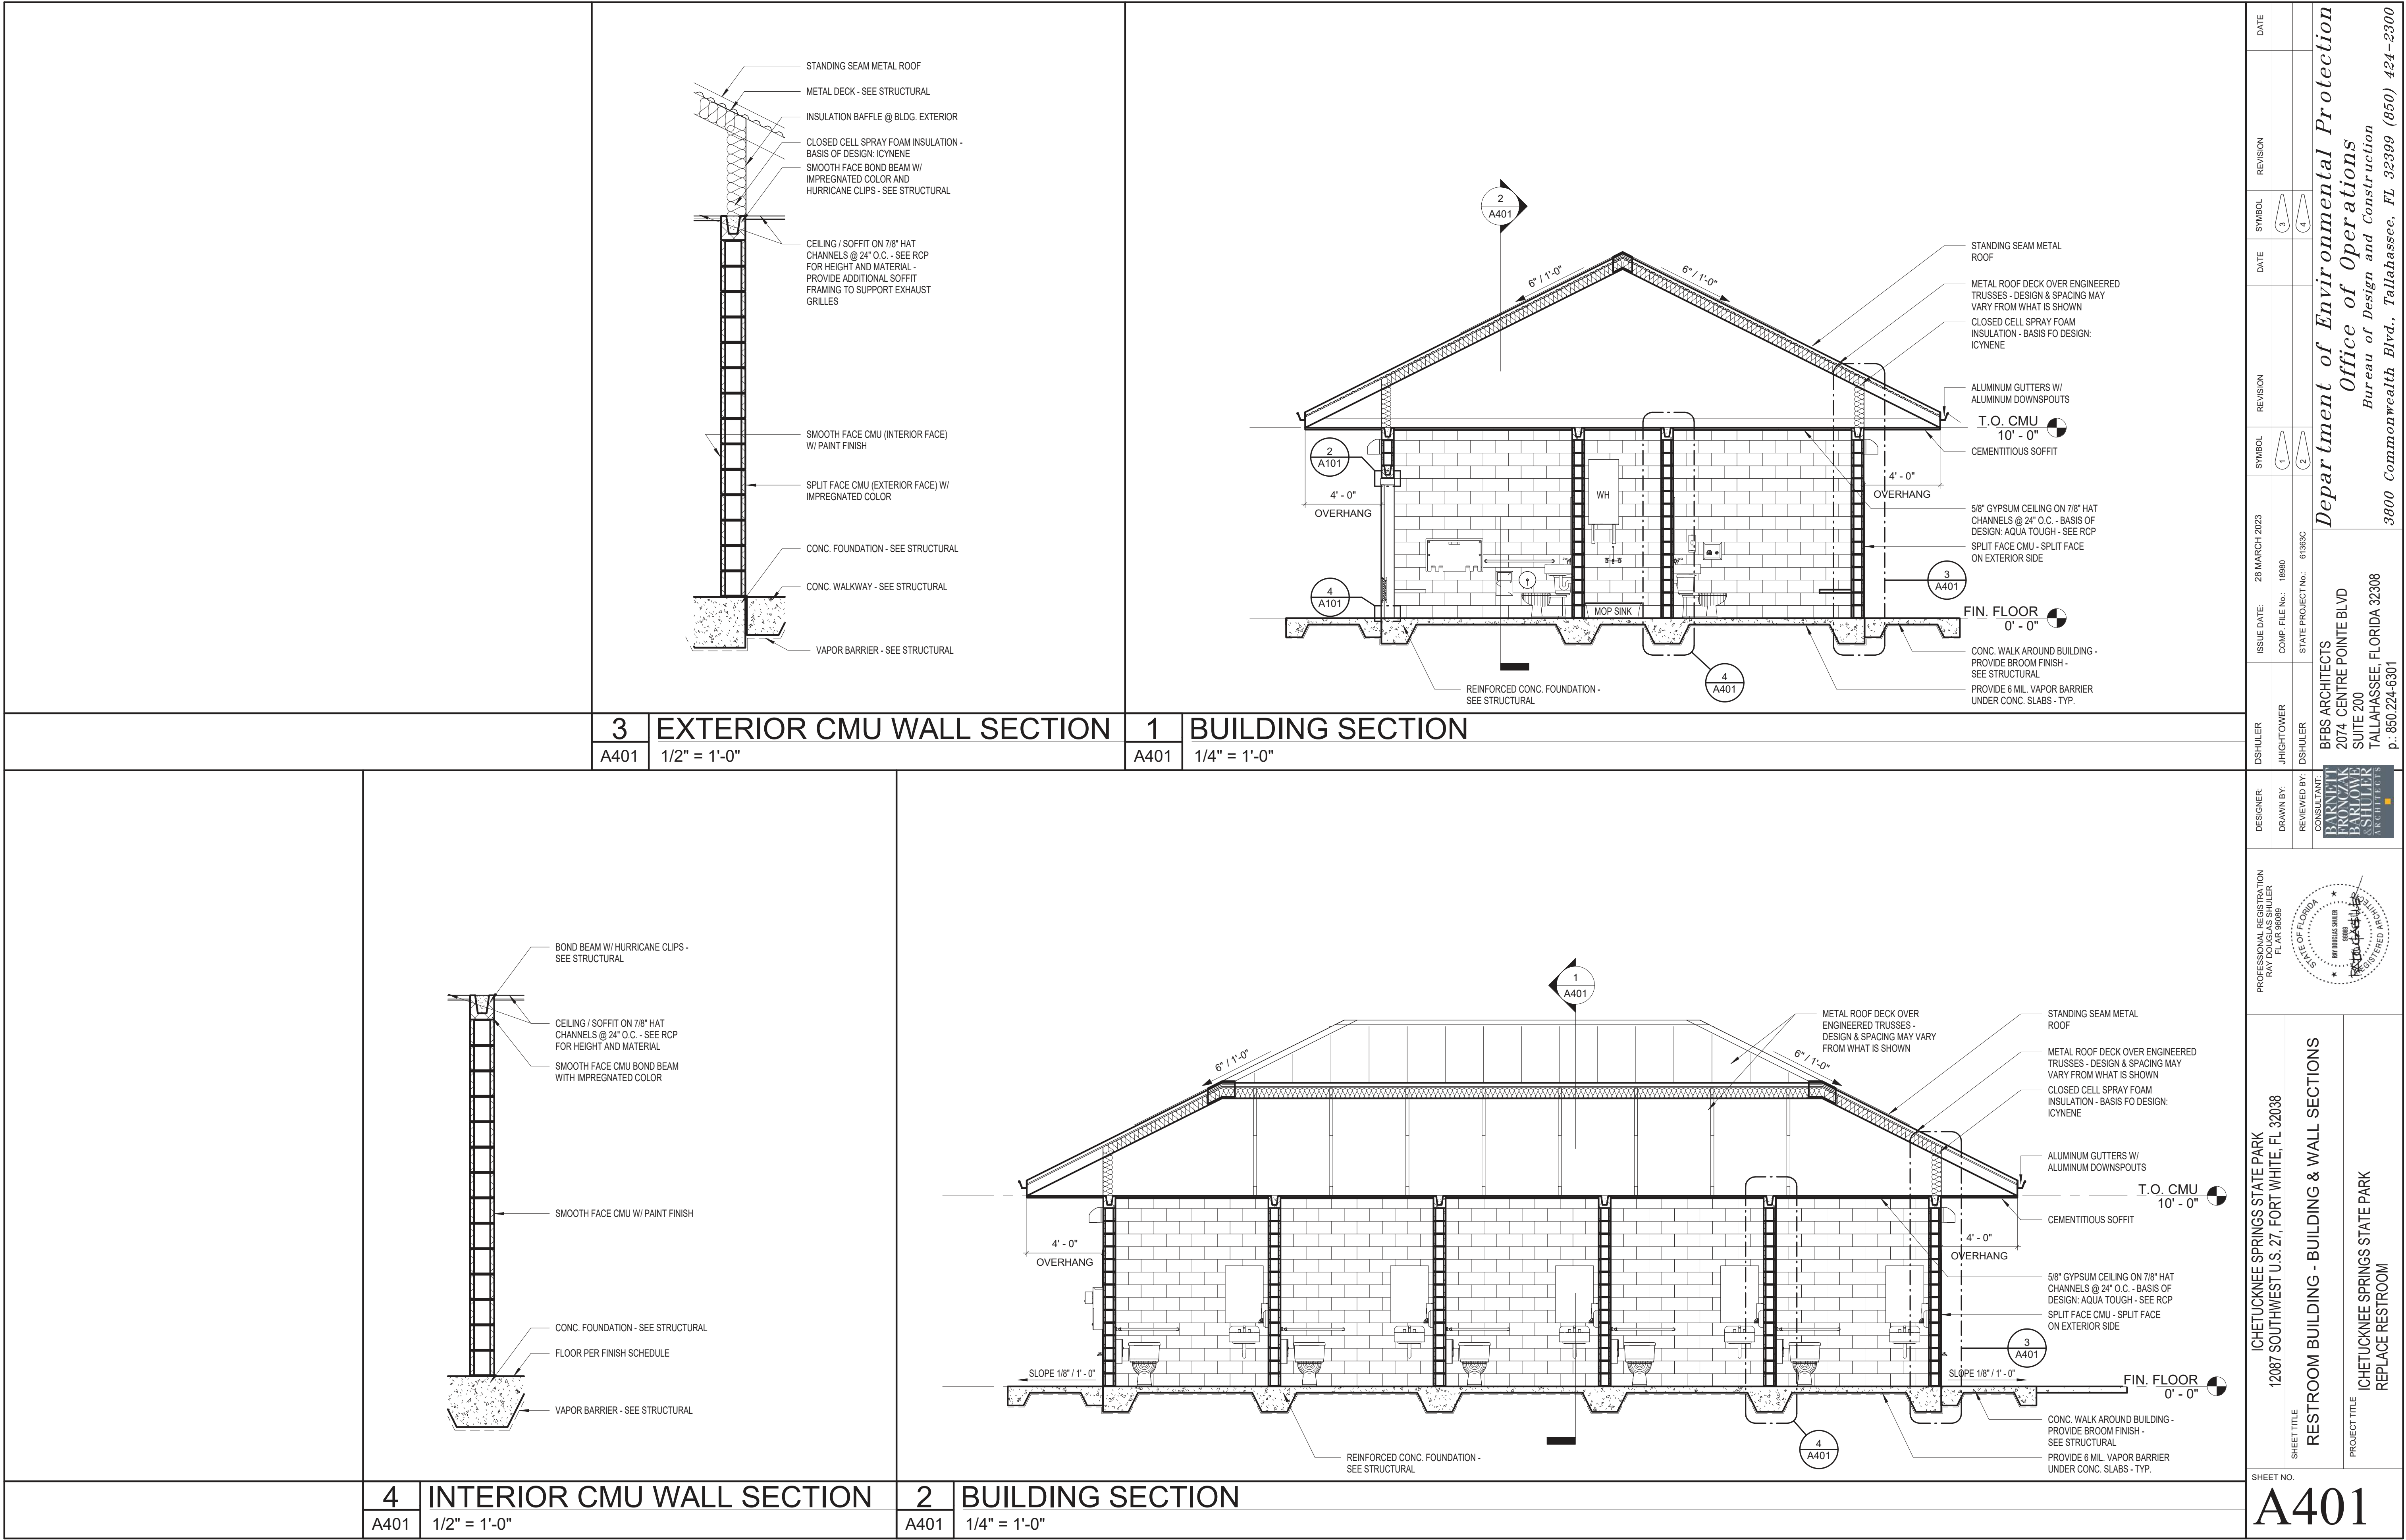

HVAC SPECIFICATIONS	
1	SUPPLY, RETURN, EXHAUST, AND OUTSIDE AIR DUCTWORK: ALL DUCTWORK SHALL BE CONSTRUCTED IN ACCORDANCE WITH THE LATEST EDITION OF SMACNA GUIDELINES AND SHALL BE CONSTRUCTED FROM G90 GALVANIZED SHEET STEEL. ALL SEAMS SHALL BE SEALED TO A MINIMUM OF 2" PRESSURE CLASS WITH WATER BASED MASTIC.
2	FLEXIBLE DUCT CONNECTORS: FLEXIBLE CONNECTORS SHALL BE LISTED FOR USE. EXTERIOR DUCT CONNECTORS SHALL BE CHEMICAL, UV, AND WEATHER RESISTANT. PROVIDE HEAVY DUTY CONNECTIONS WHERE USED FOR CONNECTIONS TO EXHAUST FANS.
3	AIR CONDITIONING SYSTEMS SHALL BE TESTED AND BALANCED UPON INSTALLATION COMPLETION BY A NEBB OR AABC CERTIFIED TEST AND BALANCE AGENT. AGENT SHALL PROVIDE A SIGNED AND SEALED TEST AND BALANCE REPORT TO THE ENGINEER OF RECORD UPON COMPLETION OF TAB ACTIVITIES.
4	DIFFUSERS AND GRILLES SHALL BE FROM A SINGLE MANUFACTURER. DIFFUSERS AND GRILLES SHALL BE ALL ALUMINUM CONSTRUCTION AND BE WHITE IN COLOR, UNLESS NOTED OTHERWISE.

CODE REFERENCES	
FBC, BUILDING	FLORIDA BUILDING CODE, 2020 SEVENTH EDITION
FBC, MECHANICAL	FLORIDA BUILDING CODE, 2020 SEVENTH EDITION
FBC, TEST PROTOCOL	FLORIDA BUILDING CODE, 2020 SEVENTH EDITION
FBC, EXISTING BUILDING	FLORIDA BUILDING CODE, 2020 SEVENTH EDITION
FBC, ENERGY	FLORIDA BUILDING CODE, 2020 SEVENTH EDITION
FFPC	FLORIDA FIRE PREVENTION CODE, 2020 SEVENTH EDITION
NFPA 51B	STANDARD FOR FIRE PREVENTION DURING WELDING, CUTTING, AND OTHER HOT WORK, 2014 EDITION
NFPA 70	NATIONAL ELECTRIC CODE, 2017 EDITION
NFPA 90A	STANDARD FOR THE INSTALLATION OF AIR CONDITIONING AND VENTILATING SYSTEMS, 2018 EDITION
NFPA 101	LIFE SAFETY CODE, 2018 EDITION
NFPA 101A	GUIDE ON ALTERNATIVE APPROACHES TO LIFE SAFETY, 2016 EDITION

DESIGN CRITERIA	
BUILDING TYPE	GROUP U - UTILITY
CLIMATE ZONE	2A, COLUMBIA COUNTY, FLORIDA
OUTDOOR DESIGN CONDITIONS (SUMMER)	95°F DB, 78°F WB
OUTDOOR DESIGN CONDITIONS (WINTER)	25°F DB
INTERIOR DESIGN TEMPERATURES	72°F HEATING, 75°F COOLING
ENERGY COMPLIANCE METHOD	PERSCRIPTIVE METHOD (TRADE OFF METHOD)
COMMISSIONING	COMMISSIONING IS NOT REQUIRED PER EXCEPTION #1 OF C408.2 OF FLORIDA BUILDING CODE - ENERGY, 2020 (SEVENTH EDITION).
SCOPE OF WORK	THE PROJECT CONSISTS OF A BATHROOM BUILDING. VENTILATION WILL BE PROVIDED BY CEILING MOUNTED EXHAUST FANS AND A ROOF MOUNTED EXHAUST FAN WITH OUTSIDE AIR PROVIDED THROUGH LOUVERS.


CONTROLS SYMBOLS	
FAN OR PUMP	
PREMIUM EFFICIENT MOTOR, UNO	
THERMOSTAT/ TEMPERATURE SENSOR WITH CONTROL WIRING	

ABBREVIATIONS	
AFF	ABOVE FINISHED FLOOR
AFG	ABOVE FINISHED GRADE
AFR	ABOVE FINISHED ROOF
AHJ	AUTHORITY HAVING JURISDICTION
AHU	AIR HANDLING UNIT
BHP	BRAKE HORSE POWER
CD	CONDENSATE
CFM	CUBIC FEET PER MINUTE
CU	CONDENSING UNIT
DN	DOWN
EA	EXHAUST AIR
EAT	ENTERING AIR TEMPERATURE
ESP	EXTERNAL STATIC PRESSURE
FLA	FULL LOAD AMPS
GFI	GROUND FAULT CIRCUIT INTERRUPTER
GPM	GALLONS PER MINUTE
KW	KILLOWATT
LAT	LEAVING AIR TEMPERATURE
MBH	THOUSANDS OF BTU'S PER HOUR
MCA	MINIMUM CIRCUIT AMPS
MOCP	MAXIMUM OVER CURRENT PROTECTION
NTS	NOT TO SCALE
OA	OUTDOOR AIR
PSI	POUNDS PER SQUARE INCH
PSIG	PSI GAUGE
PVC	POLYVINYL CHLORIDE
RA	RETURN AIR
SA	SUPPLY AIR
TSP	TOTAL STATIC PRESSURE
UNO	UNLESS NOTED OTHERWISE
WP	WEATHER PROOF
SIM	SIMILAR

DUCT SYMBOLS	
FLEXIBLE CANVAS CONNECTION	
EXHAUST AIR DUCTWORK UP	
EXHAUST AIR DUCTWORK DOWN	
SUPPLY AIR DUCTWORK DOWN	
SUPPLY AIR DUCTWORK UP	
RETURN AIR DUCTWORK UP	
RETURN AIR DUCTWORK DOWN	
MANUAL BALANCE DAMPER	
EXHAUST AIR GRILLE	
FLEXIBLE DUCTWORK	
SUPPLY AIR DIFFUSER	
RETURN AIR GRILLE	
DIFFUSER TAG, NEW	

GENERAL HVAC NOTES	
1	TOMAHAWK ENGINEERING AND CONSULTING, INC. SHALL NOT BE HELD RESPONSIBLE FOR ANY MISUSE AND/OR MISREPRESENTATION OF THIS SET OF DOCUMENTS.
2	THE CONTRACTOR ASSUMES RESPONSIBILITY FOR USE OF THE CONTRACT DOCUMENTS. THE CONTRACTOR SHALL MAKE HIMSELF AWARE OF PROJECT CONDITIONS AND OWNER REQUIREMENTS PRIOR TO PROCUREMENT OF EQUIPMENT AND SERVICES. CHANGES IN PROJECT COST WILL NOT BE GRANTED DUE TO FIELD CONFLICTS AND/OR PROJECT CONDITIONS.
3	THIS SET OF DRAWINGS AND SPECIFICATIONS SHALL NOT BE CONSIDERED A SET OF CONSTRUCTION DOCUMENTS UNLESS A SIGNATURE AND DATE ARE AFFIXED TO THE DRAWINGS AND SPECIFICATIONS BY THE ENGINEER IN RESPONSIBLE CHARGE FOR THE GIVEN DISCIPLINE.
4	CONFLICTS BETWEEN THIS SET OF DRAWINGS AND THE CONTRACT SPECIFICATIONS SHALL BE RESOLVED BY THE ENGINEER OF RECORD. THE CONTRACTOR DOES NOT HAVE THE AUTHORITY TO INTERPRET CONFLICTS AND RESOLVE ISSUES WITHOUT WRITTEN DIRECTION FROM THE ENGINEER OF RECORD.
5	ANY CONFLICTS IN THE FIELD OR WITHIN THESE DOCUMENTS SHALL BE RECORDED AND PROVIDED TO THE ENGINEER OF RECORD ON THE CONTRACTOR'S STANDARD LETTERHEAD. WRITTEN DIRECTION RESOLVING CONFLICT WILL BE ISSUED BY THE ENGINEER OF RECORD.
6	WHERE THE CONTRACTOR DEVIATES FROM THIS SET OF CONSTRUCTION DOCUMENTS AND RESUBMISSION OF REVISED DRAWINGS IS REQUIRED BY THE PERMITTING OFFICE/OFFICIAL, A MINIMUM CHARGE OF \$750.00 PER AFFECTED DRAWING SHEET WILL BE BILLED TO THE CONTRACTOR. THE REVISED DRAWINGS WILL NOT BE PROVIDED AND/OR SUBMITTED TO THE PERMIT OFFICE UNTIL A PURCHASE ORDER OR SIGNED AGREEMENT IS ISSUED BY THE CONTRACTOR TO THE DESIGN PROFESSIONAL FOR WORK REQUIRED. THIS SHALL NOT APPLY TO UNFORESEEN CONDITIONS OR CHANGES REQUIRED FOR THE PROJECT THAT ARE NOT INITIATED BY THE CONTRACTOR.
7	DRAWINGS ARE SCHEMATIC IN NATURE. THE CONTRACTOR SHALL COORDINATE WITH OTHER TRADES AND EXISTING EQUIPMENT (WHERE APPLICABLE) TO ENSURE EQUIPMENT FURNISHED WILL WORK FOR SPACES PROVIDED. FINAL DIMENSIONS OF DUCTWORK AND PIPING SHALL BE COORDINATED IN FIELD. THE CONTRACTOR ASSUMES ALL RESPONSIBILITY FOR PROVIDING OFFSETS AND TRANSITIONS IN DUCTWORK AND PIPING TO FIT IN SPACES PROVIDED AND THESE ADDITIONAL OFFSETS AND TRANSITIONS SHALL BE PROVIDED AT NO ADDITIONAL COST TO THE OWNER.
8	DUCTWORK SHALL BE CONSTRUCTED IN ACCORDANCE WITH THE LATEST EDITION OF SMACNA GUIDELINES AT TIME OF PROJECT PERMIT.
9	THERMOSTATS, HUMIDISTATS, TEMPERATURE SENSORS, HUMIDITY SENSORS, AND/OR OTHER DEVICES REQUIRING OCCUPANT ADJUSTMENT BUT LOCATED ON WALL SHALL BE MOUNTED 48" AFF, UNLESS NOTED OTHERWISE.
10	WHERE APPLICABLE AND AVAILABLE, ACTUAL EQUIPMENT DRAWINGS ARE USED FOR SYMBOLS ON PLAN VIEWS AND IN DETAILS. HOWEVER, SIMPLE BLOCK DIAGRAMS WITH ESTIMATED DIMENSIONS ARE ALSO USED FOR PLAN VIEWS. WHERE EQUIPMENT OR DEVICES ARE NOT LABELED, INDUSTRY STANDARD TERMINOLOGY AND SYMBOLOGY SHALL APPLY.
11	THESE GENERAL NOTES WORK IN CONJUNCTION WITH NOTES SHOWN ON PLAN VIEWS. THESE NOTES DO NOT SUPERCEDE NOTES SHOWN ON PLAN VIEW DRAWINGS. CONVERSELY, NOTES SHOWN ON PLAN VIEW DRAWINGS DO NOT SUPERCEDE THESE GENERAL NOTES.
12	REFER TO EQUIPMENT SCHEDULES FOR AIR AND WATER PRESSURE DROPS ASSOCIATED WITH COOLING AND HEATING COILS.
13	PROVIDE ACCESS PANELS IN DUCTWORK AND/OR BUILDING CONSTRUCTION WHERE REQUIRED FOR EQUIPMENT ACCESS AND SERVICE. PANELS SHALL BE SIZED TO SUIT EQUIPMENT SERVICED. WHERE PANELS WILL BE LOCATED IN FIRE RATED WALLS AND/OR PARTITIONS, THE ACCESS PANEL SHALL MEET THE RATING OF THE WALL. REFER TO ARCHITECTURAL DRAWINGS FOR RATINGS OF WALLS AND PARTITIONS.
14	UNLESS NOTED OTHERWISE, DUCTWORK, PIPING, VALVES, DAMPERS, AND ALL ASSOCIATED ANCILLARY HVAC DEVICES SHALL BE CONSTRUCTED IN ACCORDANCE WITH MECHANICAL SPECIFICATIONS. ALL EQUIPMENT INSTALLED AS PART OF THIS PROJECT SHALL BE NEW, UNLESS NOTED OTHERWISE, NO EXCEPTIONS.
15	PAINT DUCTWORK AND DAMPERS VISIBLE THRU REGISTERS FLAT BLACK PRIOR TO OWNER OCCUPANCY.
16	HVAC EQUIPMENT PROVIDED FROM THIRD PARTY MANUFACTURER SHALL BE INSTALLED IN ACCORDANCE WITH THE MANUFACTURER'S WRITTEN INSTALLATION INSTRUCTIONS. WHERE CONFLICTS BETWEEN CONTRACT DOCUMENTS AND MANUFACTURER'S INSTRUCTION ARISE, THE MANUFACTURER'S INSTALLATION INSTRUCTIONS SHALL PREVAIL.
17	THE CONTRACTOR SHALL MAKE HIS OR HERSELF AWARE OF THE OWNER'S SCHEDULE AND BE PREPARED TO WORK AT NIGHT OR ON WEEKENDS TO COMPLETE WORK SHOWN IN THESE DOCUMENTS. INTERRUPTIONS TO OWNER'S NORMAL WORK SCHEDULE SHALL NOT BE MADE WITHOUT WRITTEN INSTRUCTION TO DO SO FROM OWNER'S REPRESENTATIVE.
18	WHERE THERE ARE CONFLICTS BETWEEN LIGHT SWITCHES AND THERMOSTAT/HUMIDISTAT LOCATIONS, THE LIGHT SWITCHES SHALL PREVAIL. MOUNT THERMOSTAT/HUMIDISTATS ADJACENT TO LIGHT SWITCHES.
19	AS REQUIRED BY BUILDING CONSTRUCTION, THE CONTRACTOR SHALL PROVIDE TRANSITIONS AND EQUIVALENT SQUARE DUCT SIZES NEEDED TO FIT THRU JOISTS AND/OR WALL 2x4 SPACING WHERE ROUND IS SHOWN ON PLANS. THE CONTRACTOR SHALL PROVIDE THESE TRANSITIONS AND SQUARE DUCTS AT NO ADDITIONAL COST TO THE OWNER. COORDINATE WITH THE GC IN FIELD FOR JOIST AND WALL 2x4 REQUIREMENTS.
20	WHERE REQUIRED BY BUILDING CONSTRUCTION AND HEIGHT TO EQUIPMENT SERVED, THE CONTRACTOR SHALL PROVIDE HOISTING MECHANISMS AS WELL AS SCAFFOLDING WHERE REQUIRED TO INSTALL EQUIPMENT SHOWN WITHIN THESE CONTRACT DOCUMENTS. EQUIPMENT USED FOR THE INSTALLATION OF EQUIPMENT SHALL MEET ALL OSHA REQUIREMENTS.
21	PROVIDE MANUAL BALANCE DAMPERS FOR SUPPLY, RETURN, AND EXHAUST TAKE-OFFS TO REGISTERS WHETHER INDICATED OR NOT. WHERE DAMPERS WILL BE LOCATED ABOVE INACCESSIBLE CEILINGS, PROVIDE OPPOSED BLADE MANUAL BALANCE DAMPERS FROM REGISTER MANUFACTURER.

THIS ITEM HAS BEEN ELECTRONICALLY SIGNED AND SEALED BY THE ENGINEER INDICATED HEREIN WITH THE DATE AND INDICATED IN THE TIME STAMP USING AN RSA CODE. PRINTED COPIES OF THIS DOCUMENT ARE NOT CONSIDERED SIGNED AND SEALED AND THE SIGN AUTHENTICATION CODE MUST BE VERIFIED ON ANY ELECTRONIC COPIES.

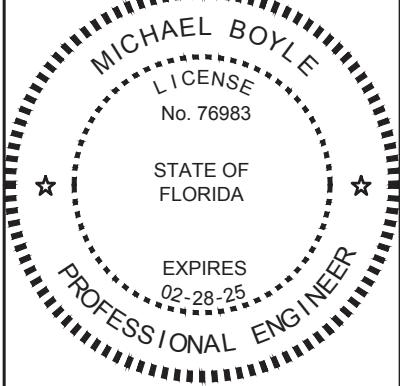

SHEET TITLE	ICHETUCKNEE SPRINGS STATE PARK 12087 SOUTHWEST U.S. 27, FORT WHITE, FL 32038
PROJECT TITLE	ICHETUCKNEE SPRINGS STATE PARK REPLACE RESTROOM
LEGEND, NOTES & SCHEDULES - HVAC	

SHEET NO.
M001




DESIGNER : DMM	DRAWN BY: DMM	ISSUE DATE: 28 MARCH 2023	REVISION	DATE
REVIEWED BY: WHT	Consultant :	COMP. FILE No.: 18180	SYMBOL	DATE
		STATE PROJECT No.: 61383C	1	2
TOMAHAWK ENGINEERING & CONSULTING, INC. 1940 Buford Blvd. - Tallahassee, FL 32302 Phone: 850-402-3040, Fax: 850-402-9699 Certificate of Authorization #: 29709 Tallahawki Project #: 22033				

Department of Environmental Protection
Office of Operations
Bureau of Design and Construction
3800 Commonwealth Blvd., Tallahassee, FL 32399 (850) 425-2300


FAN SCHEDULE										
EQUIPMENT NO.	MODEL NO.	FAN TYPE	CFM	EXT. STATIC	FAN RPM	DRIVE TYPE	SONES	MOTOR RPM	MOTOR HP (W)	VOLTAGE/ PHASE
EF1-1	GC-148	CEILING MOUNTED	100	0.35"	951	DIRECT	2.0	1100	(40 W)	115/1Ø
EF1-2	GC-148	CEILING MOUNTED	100	0.35"	951	DIRECT	2.0	1100	(40 W)	115/1Ø
EF1-3	GC-148	CEILING MOUNTED	100	0.35"	951	DIRECT	2.0	1100	(40 W)	115/1Ø
EF1-4	GC-148	CEILING MOUNTED	100	0.35"	951	DIRECT	2.0	1100	(40 W)	115/1Ø
EF1-5	GC-148	CEILING MOUNTED	100	0.35"	951	DIRECT	2.0	1100	(40 W)	115/1Ø
EF1-6	GC-148	CEILING MOUNTED	100	0.35"	951	DIRECT	2.0	1100	(40 W)	115/1Ø
EF1-7	GC-148	CEILING MOUNTED	100	0.35"	951	DIRECT	2.0	1100	(40 W)	115/1Ø
EF1-8	GC-148	CEILING MOUNTED	100	0.35"	951	DIRECT	2.0	1100	(40 W)	115/1Ø
EF1-9	GC-148	CEILING MOUNTED	100	0.35"	951	DIRECT	2.0	1100	(40 W)	115/1Ø
EF1-10	GC-148	CEILING MOUNTED	100	0.35"	951	DIRECT	2.0	1100	(40 W)	115/1Ø
EF1-11	GC-166	CEILING MOUNTED	125	0.35"	1045	DIRECT	2.5	1100	(46 W)	115/1Ø
EF1-12	GC-166	CEILING MOUNTED	125	0.35"	1045	DIRECT	2.5	1100	(46 W)	115/1Ø
NOTES:										
1.	BASIS OF DESIGN: LOREN COOK, OR EQUAL.									
2.	PROVIDE EXHAUST FANS, EF1-1 THRU EF1-10 WITH THE FOLLOWING: DISCONNECT SWITCH (REFER TO ELEC.), HANGING SUPPORT KIT, BACK DRAFT DAMPER, WHITE PLASTIC GRILLE, SPEED CONTROLLER, VIBRATION ISOLATORS. TIE EXHAUST FANS INTO LIGHTING CIRCUIT, REFER TO ELEC. DRAWINGS.									
3.	PROVIDE EXHAUST FAN, EF1-11 & EF1-12 WITH THE FOLLOWING: DISCONNECT SWITCH (REFER TO ELEC.), HANGING SUPPORT KIT, BACK DRAFT DAMPER, WHITE PLASTIC GRILLE, SPEED CONTROLLER, VIBRATION ISOLATORS AND LINE VOLTAGE THERMOSTAT. INITIALLY SET THERMOSTAT TO 80°F.									

DIFFUSER SCHEDULE			
PLAN MARK	CFM	NECK SIZE	DESCRIPTION
A	GRILLES TO BE 16x14		ALL ALUMINUM HEAVY DUTY CONSTRUCTION SIGHT PROOF TRANSFER GRILLE. GRILLE TO BE EXTRUDED ALUMINUM, MANDREL TUBE CONSTRUCTION AND ANGLED LOUVERED BLADES. PROVIDE GRILLE WITH MOUNTING KIT FOR DOOR. COORDINATE WITH ARCHITECTURAL DRAWINGS FOR DOOR SCHEDULE. GRILLE SHALL BE EQUAL TO PRICE MODEL ATGH.
B	REFER TO PLAN VIEWS FOR CFM AND SIZES		ALL ALUMINUM CONSTRUCTION RETURN/EXHAUST AIR, WITH LOUVERED FACE AND 3/4" BLADE SPACING ON 45° ANGLE. PROVIDE LAY-IN TYPE BORDER WHERE LOCATED IN LAY-IN TYPE CEILINGS. PROVIDE WITH SURFACE MOUNTED BORDER WHERE LOCATED IN GYPSUM CEILINGS OR ON WALLS. GRILLE SHALL BE EQUAL TO PRICE MODEL 630.
NOTES:			
1. LAY-IN AND WALL MOUNTED DIFFUSERS AND GRILLES SHALL BE WHITE.			
2. WHERE REQUIRED BY GYPSUM CEILINGS, PROVIDE WITH PLASTER RINGS OR OTHER APPURTENANCES AS REQUIRED.			
3. INTERIORS OF DIFFUSERS AND GRILLES VISIBLE FROM THE FINISHED SPACE SHALL BE PAINTED FLAT BLACK.			

ELECTRIC UNIT HEATER SCHEDULE							
EQUIPMENT NO.	QUANTITY	MODEL NO. (CDIR SERIES)	KILOWATTS	TOTAL AMPS	CFM	APPROXIMATE AIR TEMP. RISE (°F)	VOLTAGE/PHASE
EUH1-1	1	937U03000J	3	13.2	310	60	240/1Ø
NOTES:							
1.	BASIS OF DESIGN: INDEECO OR EQUAL.						
2.	PROVIDE UNIT HEATERS WITH FAN ON/AUTO SWITCH, FACTORY BUILT-IN DISCONNECT SWITCH RATED FOR UNIT HEATER, STEEL FINNED TUBULAR ELEMENTS, AND CEILING MOUNTED KIT. COLOR TO BE SELECTED BY ARCHITECT.						
3.	TRIM KITS SHALL BE TAMPER PROOF AND PROVIDED WITH ANTI LIGATURE COMPONENTS. THERMOSTATS SHALL BE INTERNALLY MOUNTED AND NOT ADJUSTABLE FROM EXTERIOR OF UNIT. INITIALLY SET THERMOSTATS TO 70°F.						

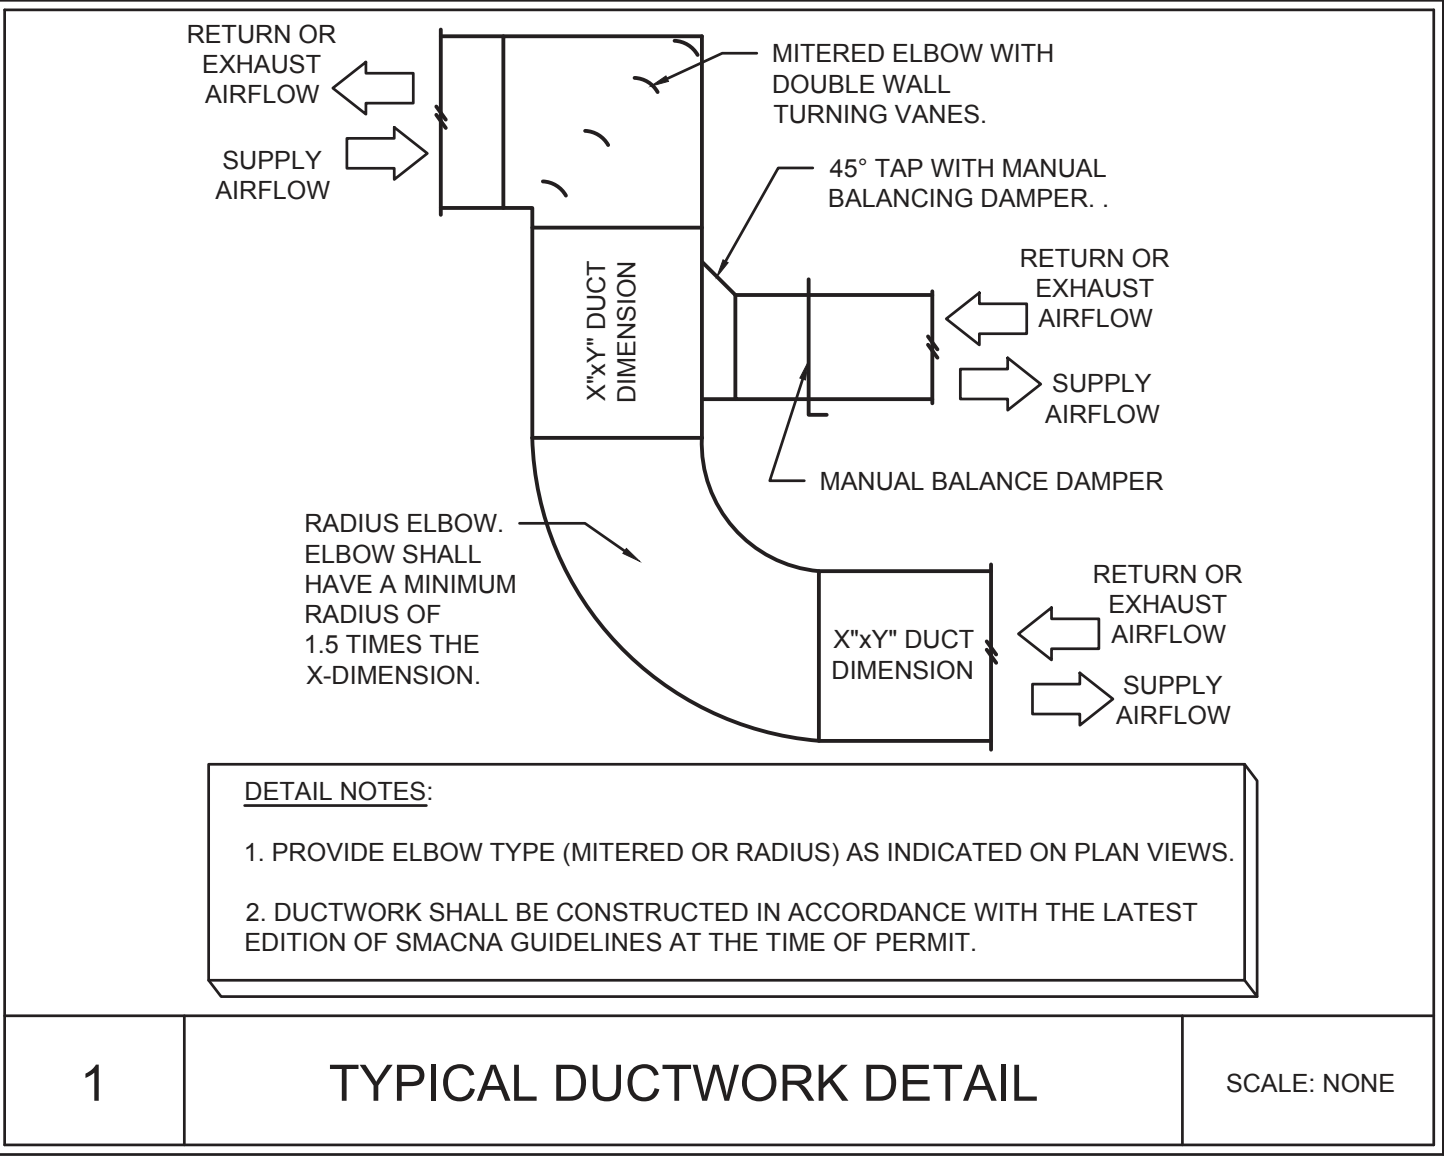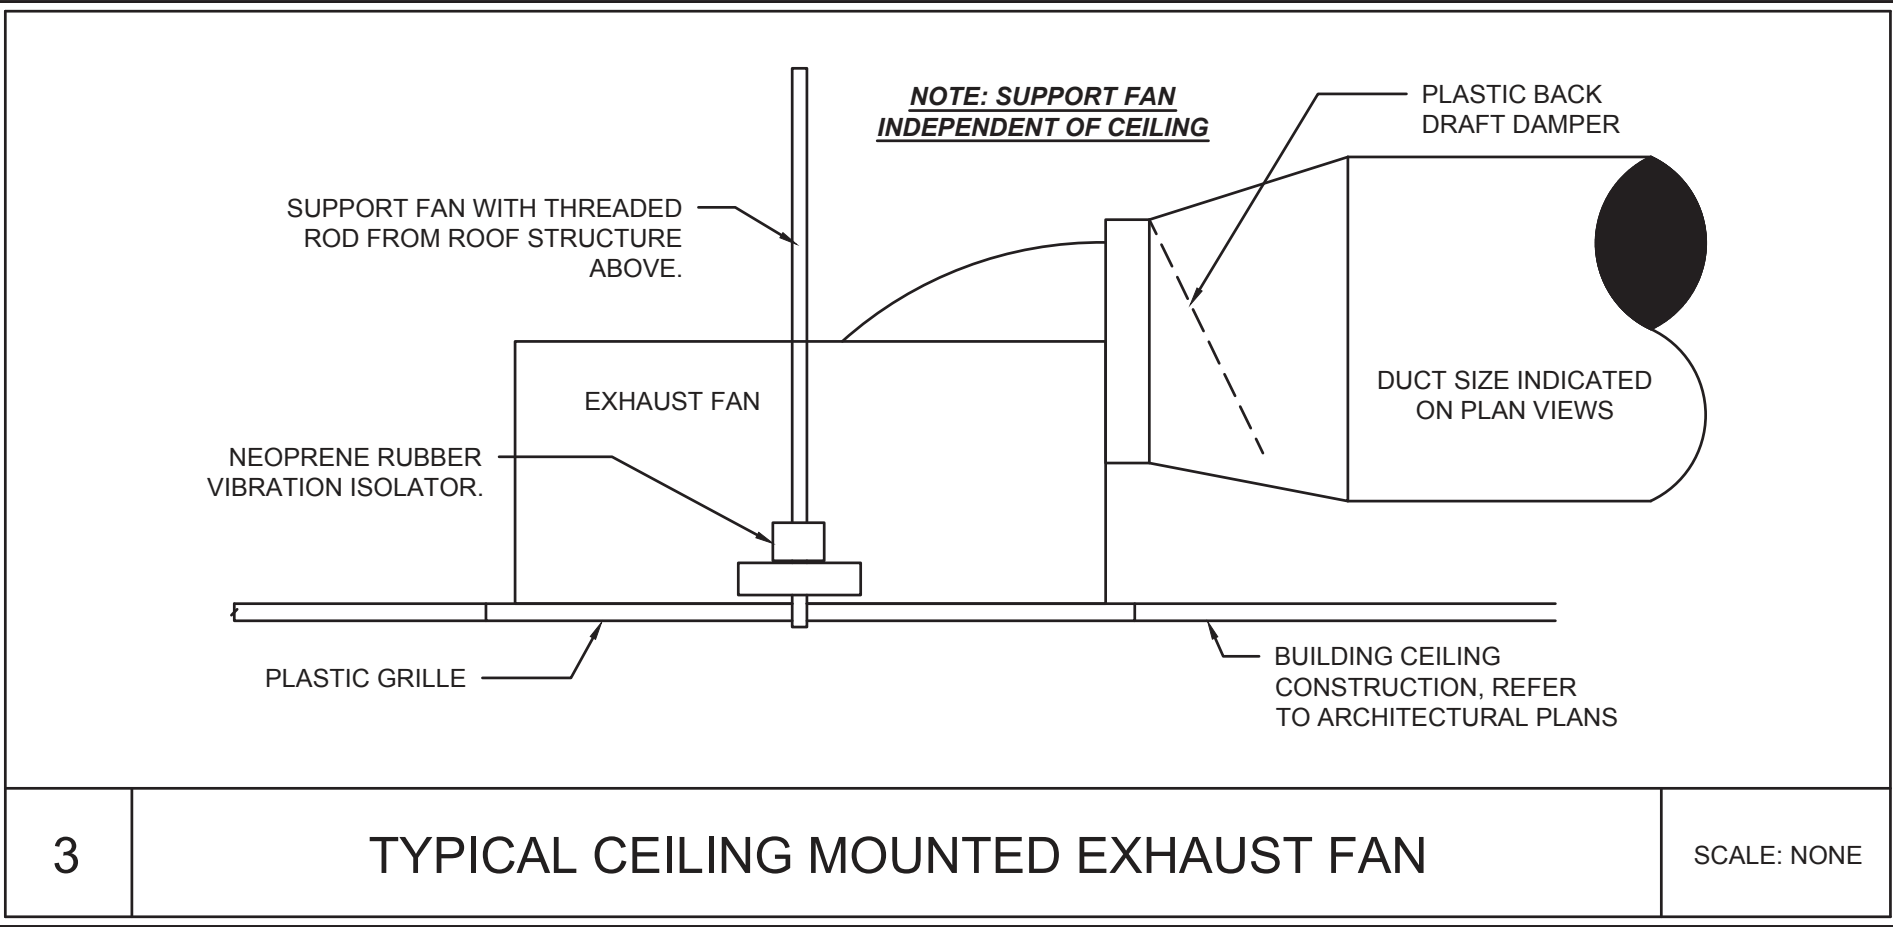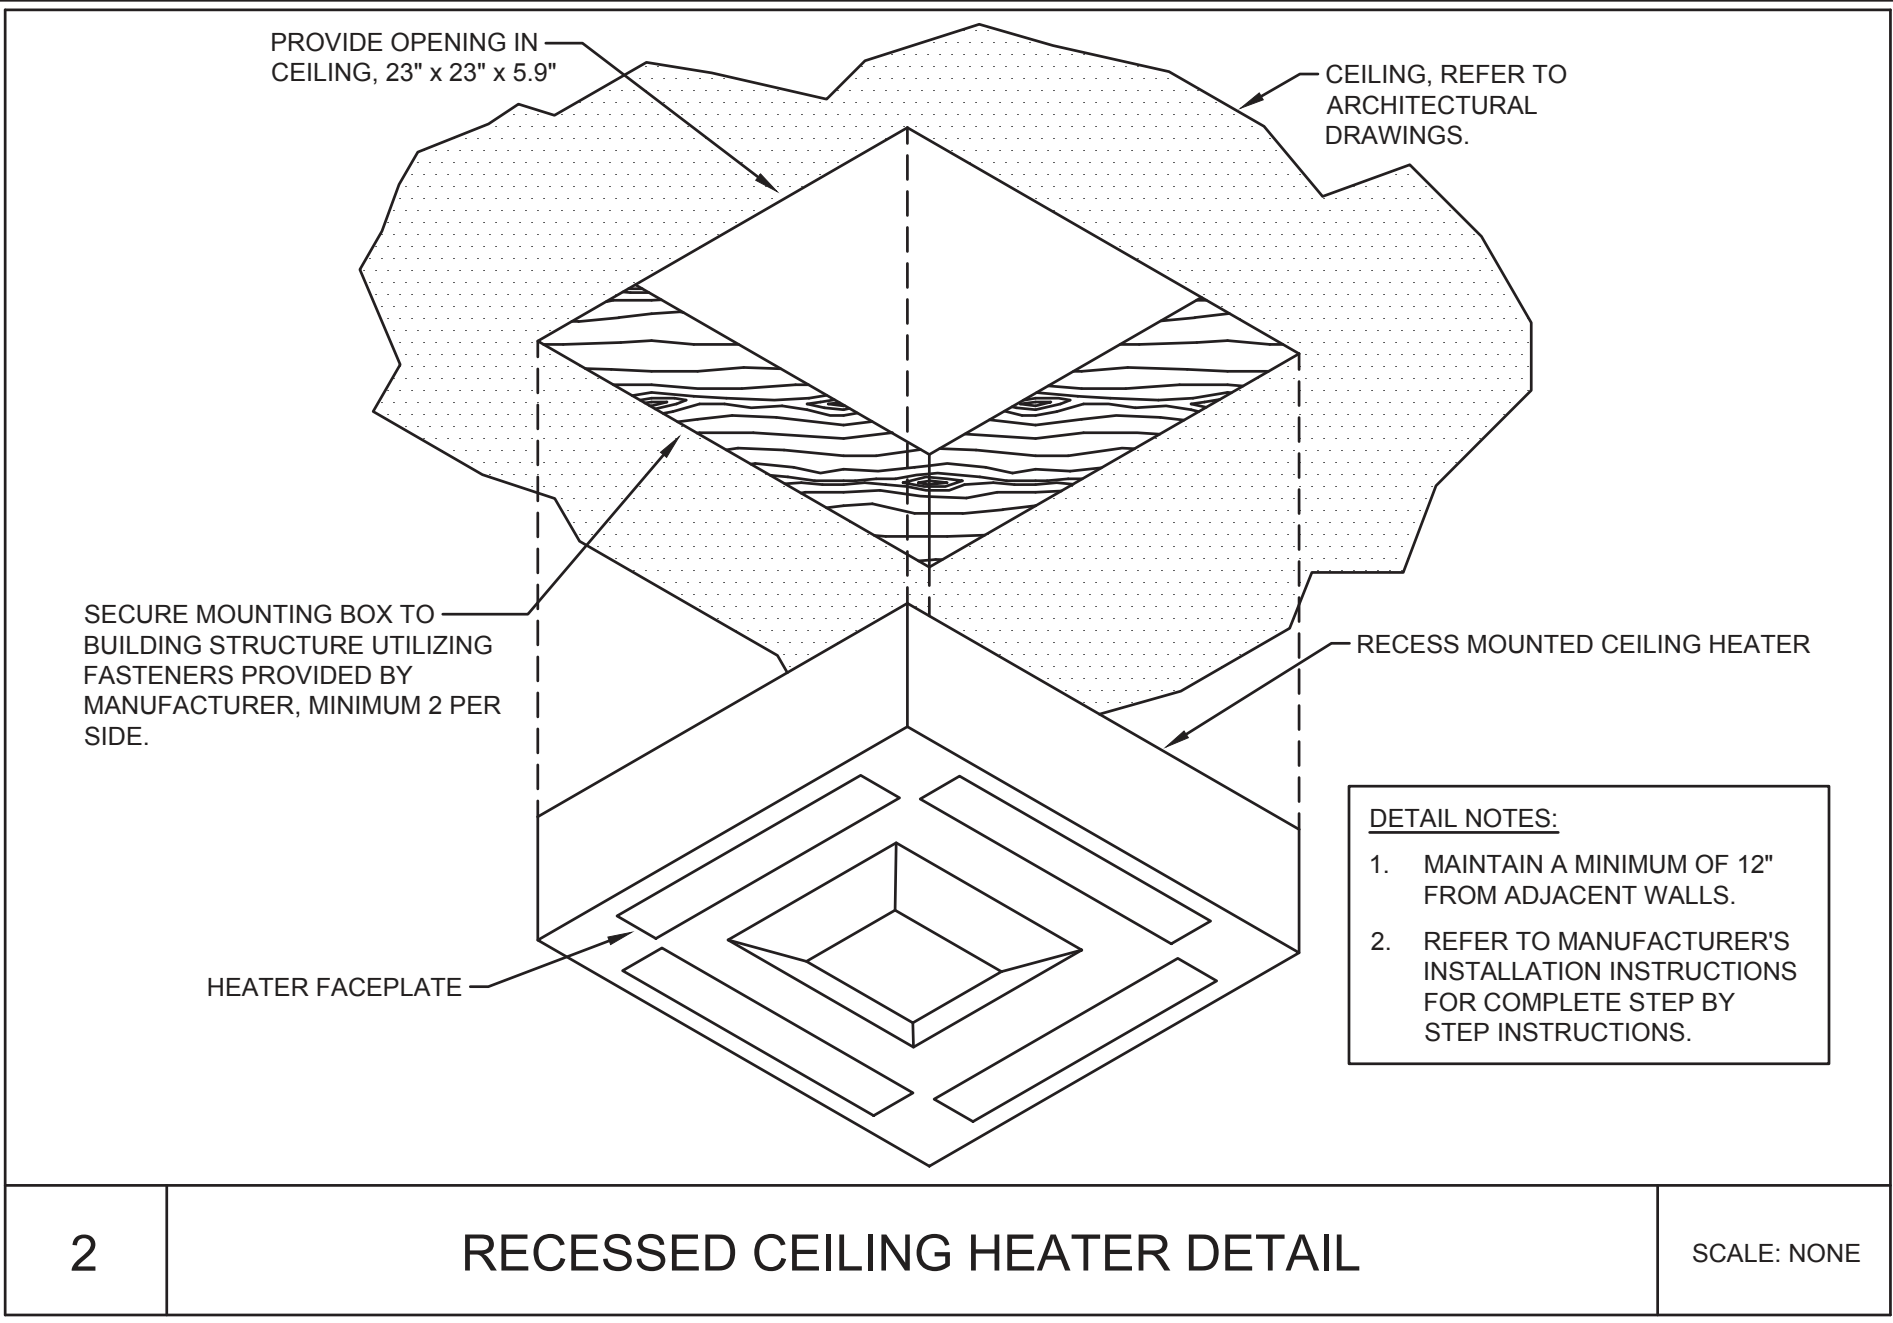

THIS ITEM HAS BEEN ELECTRONICALLY SIGNED AND SEALED BY THE ENGINEER INDICATED HEREIN WITH THE DATE AND INDICATED IN THE TIME STAMP USING AN RSA CODE. PRINTED COPIES OF THIS DOCUMENT ARE NOT CONSIDERED SIGNED AND SEALED AND THE SIGN AUTHENTICATION CODE MUST BE VERIFIED ON ANY ELECTRONIC COPIES.

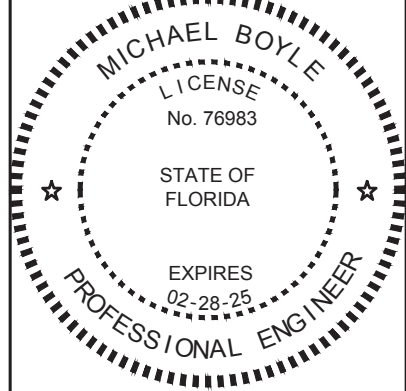

DESIGNER :	DMM	ISSUE DATE:	28 MARCH 2023	STATE PROJECT NO.:	61363C
DRAWN BY:	DMM	COMP. FILE NO.:	16880	TOMAHAWK ENGINEERING & CONSULTING, INC.	
REVIEWED BY:	WHT	1940 Buford Blvd. - Tallahassee, FL 32302		Office of Environmental Protection	
Consultant :		Richard Lindburg		Office of Operations	
		PER 62829		Bureau of Design and Construction	
		MICHAEL BOYLE		3800 Commonwealth Blvd., Tallahassee, FL 32399	
		PER 76983		(850) 425-2300	
				Tomahawk Project #: 22033	

SHEET NO.	M501
-----------	------

PLUMBING FIXTURE SCHEDULE:

(WC-1)	PROVIDE A KOHLER MODEL K-3999-UT VITREOUS CHINA TANK TYPE, FLOOR MOUNTED. WATER CLOSET WITH ELONGATED BOWL, OR EQUAL. WATER CLOSET SHALL BE A (2) PIECE TYPE WATER CLOSET WITH A MAXIMUM WATER USAGE OF 1.28 GALLONS PER FLUSH AND 16-1/2" HIGH BOWL. TANK TO BE INSULATED AND COME COMPLETE WITH TANK COVER LOCKS. PROVIDE WITH A EXTRA HEAVY SOLID PLASTIC SEAT WITH AN OPEN FRONT AND SELF-SUSTAINING STAINLESS STEEL CHECK HINGES EQUAL TO BEMIS 1655SSCT. PROVIDE COLD INLET WITH 1/4 TURN ANGLE BALL STOP WITH 1/2" IPS SWEAT INLET AND 3/8" IPS COMPRESSION OUTLET EQUAL TO BRASSCRAFT MODEL KTR19X. STOP TO BE ALL BRASS WITH REMOVABLE HANDLE RATED FOR TEMPERATURES GREATER THAN 115 DEG F. PROVIDE STOP WITH CHROME WALL ESCUTCHEON AND STAINLESS STEEL FLEXIBLE SUPPLY FROM STOP TO WATER CLOSET. PROVIDE WATER CLOSET WITH HEAVY DUTY CLOSET FLANGE MATCHING PIPING MATERIAL AND WAX RING. WATER CLOSET AND ASSOCIATED APPURTENANCES SHALL BE ADA COMPLIANT WITH FLUSH HANDLE ON WIDE SIDE OF ROOM.
(L-1)	PROVIDE A KOHLER MODEL K-2031 VITREOUS CHINA WALL HUNG LAVATORY WITH FLOOR MOUNTED CONCEALED ARM CARRIER, OVERFLOW AND SINGLE FAUCET HOLE OR EQUAL. PROVIDE CHROME PLATED 17 GAUGE 1-1/4 x 1-1/2 BRASS T-RAP WITH CLEANOUT EQUAL TO PROFLOW MODEL PFPBT104. PROVIDE OFFSET LAVATORY GRID DRAIN EQUAL TO PROFLO MODEL PFGD101. PROVIDE A CHICAGO FAUCETS MODEL 3510-E2805AB SINGLE HOLE AND SINGLE SUPPLY FAUCET. FAUCET TO HAVE SINGLE LEVER HANDLE, STAINLESS STEEL HOSE AND 0.6 GPM VANDAL PROOF NON-AERATING LAMINAR FLOW OUTLET. PROVIDE COLD INLET WITH 1/4 TURN ANGLE BALL STOP WITH 1/2" IPS SWEAT INLET AND 3/8" IPS COMPRESSION OUTLET EQUAL TO BRASSCRAFT MODEL KTR19X. STOP TO BE ALL BRASS WITH REMOVABLE HANDLE RATED FOR TEMPERATURES GREATER THAN 115 DEG F. PROVIDE STOP WITH CHROME WALL ESCUTCHEON AND STAINLESS STEEL FLEXIBLE SUPPLY FROM STOP TO FAUCET INLET. PROVIDE FULLY ADJUSTABLE CONCEALED ARM, FLOOR MOUNTED LAVATORY CARRIER, ADJUSTED TO ADA HEIGHT EQUAL TO ZURN Z1231. PROVIDE HANDICAP INSULATION. LAVATORY AND ASSOCIATED APPURTENANCES SHALL BE ADA COMPLIANT.
(MS-1)	PROVIDE A MUSTEE MODEL 63M 24" 24"x40" FIBERGLASS MOP SINK OR EQUAL. MOP SINK TO BE COMPLETE WITH INTEGRAL STAINLESS STEEL DRAIN BODY AND STAINLESS STEEL CAPS ON ALL CURBS. PROVIDE MOP HANGER CONSISTING OF 24"x3" WIDE STAINLESS STEEL PLATE WITH 3 RUBBER TOOL GRIPS, HOSE AND HOSE BRACKET, AND MUSTEE MODEL 67.2424 24"x24" STAINLESS STEEL WALL GUARD ON 2 SIDES. PROVIDE A T&S BRASS MODEL B-0665-BSTC-R CHROME PLATED BRASS FAUCET OR EQUAL. FAUCET TO BE COMPLETE WITH VACUUM BREAKER, INTEGRAL CHECK STOPS, ADJUSTABLE WALL BRACE, PAIL HOOK, AND 3/4 INCH HOSE THREAD ON SPOUT.
(WH-1)	PROVIDE A WOODFORD MODEL 67 FREEZELESS WALL HYDRANT. HYDRANT TO BE FREEZELESS, AUTOMATIC DRAINING WITH BACKFLOW PREVENTER, 3/4" INLET AND OUTLET, LOOSE KEY OPERATION AND CHROME PLATED FINISH. COORDINATE WITH WALL THICKNESS PRIOR TO ORDERING.
(FD-1)	PROVIDE A ZURN MODEL Z415B-VP FLOOR DRAIN OR EQUAL. FLOOR DRAIN SHALL HAVE A COATED CAST IRON BODY, BOTTOM OUTLET, COMBINATION REVERSIBLE CLAMP COLLAR AND ADJUSTABLE ROUND HEEL PROOF NICKEL BRONZE STRAINER, 3" OUTLET, 6" ROUND TOP, AND VANDAL PROOF. PROVIDE WITH DEEP SEAL TRAP AND TRAP PRIMER CONNECTION.
(TP-1)	PROVIDE A PRECISION PLUMBING PRODUCTS MODEL PRO1-500 OR EQUAL. TRAP PRIMER TO BE IN LINE, FLOW ACTIVATED AND ALL BRASS CONSTRUCTION. PROVIDE A PRECISION PLUMBING PRODUCTS DISTRIBUTION UNIT MODEL DU-U FOR PRIMING 2 TO 4 TRAPS.
(WHA)	PROVIDE A WATTS MODEL 15M2 WATER HAMMER ARRESTOR OR EQUAL. ARRESTOR TO BE PISTON OR BELLOWS TYPE, SUITABLE FOR DOMESTIC POTABLE WATER, PDI LISTED AND SIZED PER PDI RECOMMENDATIONS.

ABBREVIATIONS

AFF	ABOVE FINISHED FLOOR
AHAP	AS HIGH AS POSSIBLE
BF	BELOW FLOOR
BG	BELOW GRADE
CO	CLEANOUT
DCW	DOMESTIC COLD WATER
DF	DRINKING FOUNTAIN
DHW	DOMESTIC HOT WATER (120°F)
DN	DOWN
ET	EXPANSION TANK
EWC	ELECTRIC WATER COOLER
EWH	ELECTRIC WATER HEATER
FD	FLOOR DRAIN
HB	HOSE BIBB
IE	INVERT ELEVATION
IW	INDIRECT WASTE
L	LAVATORY
MS	MOP SINK
NTS	NOT TO SCALE
SAN	SANITARY WASTE (OUTSIDE OF BUILDING)
SV	SHUTOFF VALVE
U	URINAL
V	VENT
W	SANITARY WASTE (INSIDE OF BUILDING)
WC	WATER CLOSET
WCO	WALL CLEANOUT
WHA	WATER HAMMER ARRESTOR

SYMBOLS LEGEND

XX-1	PLUMBING FIXTURE TAG
	DCW PIPING
	DHW OR DTW PIPING
	DTWR PIPING
	WASTE PIPING
	VENT PIPING
	ROUND FLOOR DRAIN/SINK
	PIPE BREAK
	PIPE TURNED UP
	PIPE TURNED DOWN
	BOTTOM PIPE TAP
	PIPE CAP
	FLOOR OR GRADE CLEANOUT
	DIRECTION OF FLOW
	BALL VALVE
	CHECK VALVE
	WATER HAMMER ARRESTOR

PLUMBING SPECIFICATIONS

1	ALL PLUMBING WORK SHALL BE PERFORMED BY A LICENSED PLUMBING CONTRACTOR. ALL WORK SHALL CONFORM TO THE 2020 FBC-PLUMBING, AND ALL APPLICABLE LOCAL, STATE, AND FEDERAL CODES.
2	ABOVE & BELOW GROUND DOMESTIC VENT PIPING AND SANITARY PIPING SHALL BE SCHEDULE 40 PVC OF SIZE INDICATED ON PLAN VIEWS. PIPING SHALL BE SLOPED IN ACCORDANCE WITH FLORIDA BUILDING CODE, PLUMBING AND PROVIDED WITH SOLVENT WELDED FITTINGS. PROVIDE TRANSITION FITTINGS AND METAL TO PLASTIC FITTINGS AND APPURTENANCES WHERE REQUIRED TO CONNECT TO PLUMBING FIXTURES AS INDICATED ON PLAN VIEWS.
3	DOMESTIC HOT, TEMPERED AND COLD WATER PIPING SHALL BE ONE OF THE FOLLOWING: SCHEDULE 80 CPVC PIPING & SOLVENT WELDED SCHEDULE 80 CPVC FITTINGS OR ASTM B88 TYPE "H" COPPER PIPING OF SIZE INDICATED ON PLAN VIEWS. PIPING CONNECTIONS FOR COPPER SHALL BE WROUGHT COPPER AND SOLDERED WITH SOLDER MATERIALS SUITABLE FOR USE IN POTABLE WATER SYSTEMS AND APPROVED FOR USE BY THE FLORIDA BUILDING CODE, PLUMBING. PROVIDE TRANSITION FITTINGS AND METAL TO PLASTIC FITTINGS AND APPURTENANCES WHERE REQUIRED. ADDITIONALLY, PROVIDE SOLDERED AND THREADED NIPPLES, COUPLINGS, OR OTHER PIPING COMPONENTS REQUIRED TO CONNECT TO PLUMBING FIXTURES AS INDICATED ON PLAN VIEWS. ALL PIPING AND MATERIALS SHALL BE SUITABLE FOR USE IN POTABLE WATER SYSTEMS. CLEAN WATER PIPING AS IT IS INSTALLED AND KEEP CAPPED TO ENSURE DEBRIS AND DIRT DO NOT CONTAMINATE PIPING PRIOR TO PLACING IN SERVICE.
4	CLEAN AND DISINFECT PIPING PRIOR TO PLACING IN SERVICE ACCORDING TO THE FOLLOWING:
4.1	COMPLETELY FLUSH SYSTEM WITH CLEAN WATER UNTIL ALL DIRT AND DEBRIS ARE REMOVED AND CLEAN WATER FLOWS FREELY.
4.2	ISOLATE AND FILL SYSTEM WITH A LEAST 50 PPM CHLORINE AND LET STAND FOR A MINIMUM OF 24-HOURS.
4.3	REMOVE WATER AND ISOLATE AND FILL SYSTEM WITH 200 PPM CHLORINE AND LET STAND FOR A MINIMUM OF 3-HOURS.
4.4	FLUSH SYSTEM WITH CLEAN POTABLE WATER UNTIL CHLORINE IS NO LONGER IN SYSTEM.
4.5	SUBMIT WATER SAMPLES TO THE AUTHORITY HAVING JURISDICTION, WHERE WATER IS FOUND TO BE UNACCEPTABLE, REPEAT PROCEDURES UNTIL WATER MEETS REQUIREMENTS.
4.6	PROVIDE AND SUBMIT REPORTS OF DISINFECTION PROCEDURES.
5	PROVIDE DIELECTRIC UNIONS AND FLANGE KITS FOR CONNECTIONS OF DISSIMILAR METALS.
6	DOMESTIC COLD WATER, HOT WATER AND TEMPERED WATER PIPING SHALL BE INSULATED WITH A MINIMUM 1" THICK CLOSED-CELL FOAM INSULATION EQUAL TO ARMACEL TYPE AP ARMAFLEX TUBE INSULATION. EXTERIOR PIPING INSULATION TO BE COVERED WITH A 54 MIL THICKNESS ALUMINUM ALL SERVICE WRAP TAPED SEAMS EQUAL TO ALUMAGUARD ALL WEATHER CLADDING. PROVIDE PREFORMED ALUMINUM COVERS ON FITTINGS AND ELBOWS. INSULATION SHALL HAVE AN INSTALLED MINIMUM CONDUCTIVITY OF 0.24 BTU/IN/HR(SF*F).
7	ISOLATION VALVES FOR DOMESTIC WATER PIPING SHALL BE BRONZE, SINGLE PIECE, FULL PORT VALVES SUITABLE FOR USE IN POTABLE DOMESTIC WATER LINES AND COPPER PIPING. PROVIDE WITH STAINLESS STEEL TRIM.
8	PIPING SHALL BE SUPPORTED WITH TRAPEZE HANGERS SUPPORTED WITH THREADED ROD FROM STRUCTURE, OR FROM CLEVIS HANGERS. ALL SHALL MEET UL REQUIREMENTS AND MSS PIPING STANDARDS. ALL HANGER MATERIALS TO BE STAINLESS STEEL.
9	FLOOR CLEANOUTS SHALL MEET THE FOLLOWING REQUIREMENTS:
9.1	FLOOR: HEAVY DUTY ROUND SCORIATED NICKEL BRONZE TOP.
9.2	CARPETED FLOOR: HEAVY DUTY ROUND NICKEL BRONZE TOP RECESSED FOR CARPET.
9.3	TILE FLOOR: HEAVY DUTY ROUND SCORIATED NICKEL BRONZE TOP. PROVIDE WITH 18" SQUARE, 4" THICK COLLAR.
9.4	WOOD FLOOR: LACQUERED CAST IRON WITH 1-1/2" SECURING FLANGE AND A SATIN FINISHED NICKEL BRONZE COMBINED GASKETED ACCESS COVER AND PLUG.
10	CHECK VALVES SHALL BE SWING CHECK SUITABLE FOR USE IN DOMESTIC WATER LINES AND COPPER PIPING.

CLEANOUT SCHEDULE

	GENERAL (ALL FLOOR & EXTERIOR CLEANOUTS): DURO-COATED CAST IRON CLEANOUT WITH MEMBRANE FLANGE WITH BRONZE COUNTERSUNK PLUG. CLEANOUT CAN BE ADJUSTED TO FINISH FLOOR LEVEL AFTER CONCRETE HAS SET. COORDINATE FLOOR TYPES WITH ARCHITECTURAL PLANS.
<u>FCO</u>	<u>FLOOR</u> : HEAVY DUTY ROUND SCORIATED NICKEL BRONZE TOP. <u>ZURN - ZN1400-BP</u>
<u>FCO</u>	<u>CARPETED FLOOR</u> : HEAVY DUTY ROUND NICKEL BRONZE TOP RECESSED FOR CARPET. <u>ZURN - ZN1400-BP-CM</u>
<u>FCO</u>	<u>TILE FLOOR</u> : HEAVY DUTY ROUND NICKEL BRONZE TOP RECESSED FOR TILE. <u>ZURN - ZN1400-BP-HD-X</u>
<u>FCO</u>	<u>TERRAZZO FLOOR</u> : HEAVY DUTY ROUND NICKEL BRONZE TOP RECESSED FOR TERRAZZO. <u>ZURN - ZN1400-BP-HD-Z</u>
<u>GCO</u>	<u>EXTERIOR</u> : HEAVY DUTY ROUND SCORIATED NICKEL BRONZE TOP. PROVIDE WITH 18" SQUARE X 4" THICK CONCRETE COLLAR. <u>ZURN - ZN1406-BP-HD</u>
<u>WCO</u>	<u>WALL</u> : DURO-COATED CAST IRON CLEANOUT TEE, BRONZE COUNTERSUNK PLUG, WITH ROUND POLISHED STAINLESS STEEL COVER. <u>ZURN - Z1446-BP</u>

GENERAL PLUMBING NOTES

	THESE GENERAL CONDITIONS APPLY TO THE CONTRACTOR HOLDING THE GENERAL CONTRACT AS WELL AS ALL OTHER SUB CONTRACTORS AND AGENTS REQUIRED TO PERFORM WORK ON THIS PROJECT.
1	THE CONTRACTOR SHALL FURNISH ALL LABOR, MATERIAL, AND EQUIPMENT REQUIRED TO PROVIDE THE OWNER WITH A COMPLETE, FULLY OPERATIONAL SYSTEM. WORK AND COMPONENTS NOT INDICATED BUT IMPLIED SHALL BE PROVIDED AND BE PART OF THE CONTRACT.
2	THE CONTRACTOR SHALL PROVIDE ALL CORES AND SAW CUTS FOR WALLS AND FLOORS AS REQUIRED TO INSTALL PIPING AND SERVICES AS INDICATED ON THESE DOCUMENTS. THE CONTRACTOR SHALL MAKE THEMSELVES FAMILIAR WITH THE BUILDING SITE PRIOR TO PROVIDING A BID. EXTRAS FOR NOT FULLY UNDERSTANDING THE EXISTING CONDITIONS OR THIS SET OF DOCUMENTS WILL NOT BE GIVEN. WHERE BUILDING SERVICES PENETRATE EXTERIOR WALL, SLEEVE AND SEAL WATER AND WEATHER TIGHT.
3	WORK SHALL CONFORM TO THE FLORIDA BUILDING CODE, 2020 AND ANY OTHER APPLICABLE STATE, LOCAL, AND/OR FEDERAL CODES AND LAWS.
4	THE CONTRACTOR IS RESPONSIBLE FOR OBTAINING ALL REQUIRED PERMITS AND INSPECTIONS AND IS ALSO RESPONSIBLE FOR ALL ASSOCIATED FEES FOR SAID PERMITS AND INSPECTIONS.
5	DRAWINGS ARE DIAGRAMMATIC IN NATURE. PIPING SIZES, PIPING INVERTS, EQUIPMENT DIMENSIONS, MOUNTING HEIGHTS AND GENERAL ARRANGEMENT SHALL BE FIELD MEASURED AND VERIFIED PRIOR TO PROCUREMENT. ALL FITTINGS MAY NOT BE SHOWN. THE PLUMBING CONTRACTOR SHALL PROVIDE ALL REQUIRED FITTINGS, TAPS FOR EXISTING SANITARY AND DOMESTIC PRESSURE PIPING, TRANSITIONS, FLEXIBLE CONNECTORS, VALVES, LABOR, OR ANY OTHER WORK INDICATED OR IMPLIED FOR A FULLY FUNCTIONAL SYSTEM.
6	WHERE THE CONTRACTOR DEVIATES FROM THIS SET OF CONSTRUCTION DOCUMENTS AND RESUBMISSION OF REVISED DRAWINGS IS REQUIRED BY THE PERMITTING OFFICE/OFFICIAL, A MINIMUM CHARGE OF \$750.00 PER AFFECTED DRAWING SHEET WILL BE BILLED TO THE CONTRACTOR. THE REVISED DRAWINGS WILL NOT BE PROVIDED AND/OR SUBMITTED TO THE PERMIT OFFICE UNTIL A PURCHASE ORDER OR SIGNED AGREEMENT IS ISSUED BY THE CONTRACTOR TO THE DESIGN PROFESSIONAL FOR WORK REQUIRED. THIS SHALL NOT APPLY TO UNFORESEEN CONDITIONS OR CHANGES REQUIRED FOR THE PROJECT THAT ARE NOT INITIATED BY THE CONTRACTOR.
7	SOME PIPING MAY BE LOCATED IN WALLS THAT ARE NOT ACCESSIBLE. THE CONTRACTOR SHALL INCLUDE IN THEIR COSTS, THE CUTTING AND PATCHING OF WALLS TO ACCESS PIPING AS REQUIRED TO MAKE TIE-INS AS INDICATED HEREIN.
8	THE CONTRACTOR IS RESPONSIBLE FOR THE ENTIRE SITE DURING CONSTRUCTION ACTIVITIES. AS SUCH, THE CONTRACTOR SHALL PROVIDE ALL NECESSARY PROTECTIONS AS REQUIRED BY LAW OR OWNER REQUIREMENTS. ANY DAMAGE DONE BY THE CONTRACTOR OR SUB OF SAID CONTRACTOR SHALL BE REPAIRED AT NO COST TO THE OWNER. THIS INCLUDES, BUT IS NOT LIMITED TO, ALL BUILDING CONSTRUCTION AND ALL EQUIPMENT LOCATED WITHIN THE BUILDING OR ON SITE PREMISES.
9	WORK SHALL BE CARRIED OUT IN A NEAT WORKMAN LIKE MANNER. ALL CONSTRUCTION DEBRIS SHALL BE CLEANED UP AT THE END OF EVERY WORK DAY AND ALL CONSTRUCTION DUST SHALL BE VACUUMED UP AT THE END OF EVERY WORK DAY.
10	UNLESS NOTED OTHERWISE, ALL MATERIALS, EQUIPMENT, PIPING, FIXTURES, WIRING, CABLING, AND OTHER DEVICES REQUIRED FOR COMPLETION OF PROJECT SHALL BE NEW.
	IN GENERAL, ITEMS SHOWN ON DRAWINGS LIGHTLY COMPARED TO OTHER COMPONENTS ARE EXISTING. WHERE ITEMS ARE NOT INDICATED EXPLICITLY TO BE DEMOLISHED, IT SHALL BE ASSUMED THAT THEY ARE TO REMAIN.
11	THE CONTRACTOR SHALL GUARANTY ALL LABOR AND EQUIPMENT ASSOCIATED WITH PROJECT FOR A MINIMUM OF 1-YEAR.
12	(2) COPIES OF OPERATION AND MAINTENANCE MANUALS FOR MATERIALS AND EQUIPMENT SHALL BE PROVIDED TO THE OWNER AT PROJECT COMPLETION.
13	THE CONTRACTOR AND ALL SUBCONTRACTORS ARE RESPONSIBLE FOR EXAMINING DRAWINGS (ARCHITECTURAL, MECHANICAL, PLUMBING, ELECTRICAL, STRUCTURAL AND CIVIL) AND ACTUAL, SITE CONDITIONS PRIOR TO SUBMITTING BIDS. EXTRAS WILL NOT BE GIVEN DUE TO FAILURE TO UNDERSTAND ALL CONDITIONS INVOLVED OR DISCREPANCIES BETWEEN ACTUAL, DIMENSIONS AND CONDITIONS AND DIMENSIONS AND CONDITIONS INDICATED ON PLANS. WORK SHALL BE MODIFIED AND PROVIDED AS REQUIRED BY FIELD CONDITIONS AND THIS ADDITIONAL WORK SHALL BE CARRIED OUT AT NO COST TO THE OWNER.
14	EQUIPMENT AND FIXTURES SHALL BE INSTALLED IN ACCORDANCE WITH THE MANUFACTURER'S WRITTEN INSTRUCTIONS AND STANDARD INDUSTRY PRACTICES. WHERE DISCREPANCIES BETWEEN CONTRACT DRAWINGS AND MANUFACTURER'S REQUIREMENTS ARISE, REQUEST CLARIFICATION FROM ENGINEER.
15	PRIOR TO START-UP, PERFORM MANUFACTURER'S START-UP AND CHECKOUT PROCEDURES AND ATTACH FORMS TO OPERATION AND MAINTENANCE MANUALS.
16	PROVIDE ACCESS DOORS FOR EQUIPMENT, DAMPERS, ETC. LOCATED ABOVE GYPSUM CEILINGS OR WITHIN WALLS REQUIRING ACCESS. DOOR SIZES SHALL SUIT EQUIPMENT SERVED.
17	TRAP PRIMERS TO BE PROVIDED ON ALL FLOOR DRAINS AND WHERE INDICATED ON FLOOR SINKS.
18	REFER TO MECHANICAL DETAILS AND VENDOR DRAWINGS FOR FURTHER INFORMATION REGARDING INSTALLATION AND CONNECTION OF VENDOR PROVIDED EQUIPMENT. CONTRACTOR SHALL PROVIDE ALL COMPONENTS REQUIRED FOR A FULLY FUNCTIONAL, LEAK FREE INSTALLATION.

CODE REFERENCES

FBC, BUILDING	FLORIDA BUILDING CODE, 2020 SEVENTH EDITION
FBC, MECHANICAL	FLORIDA BUILDING CODE, 2020 SEVENTH EDITION
FBC, PLUMBING	FLORIDA BUILDING CODE, 2020 SEVENTH EDITION
FBC, TEST PROTOCOL	FLORIDA BUILDING CODE, 2020 SEVENTH EDITION
FBC, ENERGY	FLORIDA BUILDING CODE, 2020 SEVENTH EDITION
FFPC	FLORIDA FIRE PREVENTION CODE, 2020 SEVENTH EDITION
NFPA 51B	STANDARD FOR FIRE PREVENTION DURING WELDING, CUTTING, AND OTHER HOT WORK, 2014
NFPA 70	NATIONAL ELECTRIC CODE, 2017 EDITION
NFPA 101	LIFE SAFETY CODE, 2018 EDITION
NFPA 101A	GUIDE ON ALTERNATIVE APPROACHES TO LIFE SAFETY

WATER HEATER SCHEDULE

EQUIPMENT NO.	MODEL NO.	FUEL SUPPLY (GAS OR ELEC)	STORAGE CAPACITY (GALLONS)	ELECTRIC ELEMENTS (#) KW	TOTAL OPERATING KW	RECOVERY @ 60°F RISE (GALLONS)	SET TEMP. °F	MIN. EFF.	VOLTS-PHASE	FLA	NOTES
EWH-1	DEL-30	ELEC	30	(1) 4.5	4.5	31	120	99%	240V-1Ø	18.8	1,2,3,4,5,6
NOTES:											
1.	BASIS OF DESIGN: A.O. SMITH (EQUAL MANUFACTURERS: BRADFORD WHITE, LOCHINVAR, STATE)										
2.	PROVIDE HEATER WITH A TEMPERATURE AND PRESSURE RELIEF VALVE SIZED BY THE UNIT MANUFACTURER.										
3.	PROVIDE UNIT WITH EXPANSION TANK (ET). SEE EXPANSION TANK SCHEDULE.										
4.	PROVIDE UNIT WITH WALL MOUNTING BRACKET AND DRAIN PAN. SEE DETAIL #3/P501.										
5.	PROVIDE HEATER WITH A VACUUM BREAKER SIZED BY THE UNIT MANUFACTURER AS REQUIRED.										
6.	PROVIDE UNIT WITH DRAIN PAN.										


EXPANSION TANK SCHEDULE

EQUIPMENT NO.	SYSTEM SERVED	MODEL NO.	TANK VOLUME (GALLONS)	ACCEPTANCE FACTOR (%)	SYSTEM TEMP. MAX./MIN.	INITIAL FILL PRESSURE	ASME RATED	MAXIMUM SYSTEM PRESSURE	NOTES
ET-1	DOMESTIC HOT WATER	ST-5C	2.0	45%	60°F/120°F	40 PSI	NO	150 PSI	1
NOTES:									
1.	BASIS OF DESIGN: AMTROL								

THIS ITEM HAS BEEN ELECTRONICALLY SIGNED AND SEALED BY THE ENGINEER INDICATED HEREIN WITH THE DATE AS INDICATED IN THE TIME STAMP USING AN SHA CODE
PRINTED COPIES OF THIS DOCUMENT ARE NOT CONSIDERED SIGNED AND SEALED AND THE SHA AUTHENTICATION CODE MUST BE VERIFIED ON ANY ELECTRONIC COPIES.

SHEET NO.		PROJECT TITLE		SHEET TITLE		DESIGNER : TKE		ISSUE DATE: 28 MARCH 2023		SYMBOL		REVISION		DATE	
P001		12087 SOUTHWEST U.S. 27, FORT WHITE, FL. 32038		LEGEND, NOTES, DETAILS & SCHEDULES - PLUMBING		DRAWN BY: TKE		COMP. FILE No.: 18860		1		3			
		12087 SOUTHWEST U.S. 27, FORT WHITE, FL. 32038		LEGEND, NOTES, DETAILS & SCHEDULES - PLUMBING		REVIEWED BY: WHT		STATE PROJECT No.: 61383C		2		4			
		12087 SOUTHWEST U.S. 27, FORT WHITE, FL. 32038		LEGEND, NOTES, DETAILS & SCHEDULES - PLUMBING		CONSULTANT : TOMAHAWK ENGINEERING & CONSULTING, INC.		RICHARD LINDBURG 1940 Buford Blvd., Tallahassee, FL 32302 Phone: 850-402-3040, Fax: 850-402-9659 MICHAEL BOYLE Certificate of Authorization #: 29709 Tomahawk Project #: 22033							


100% CONTRACT DOCUMENTS

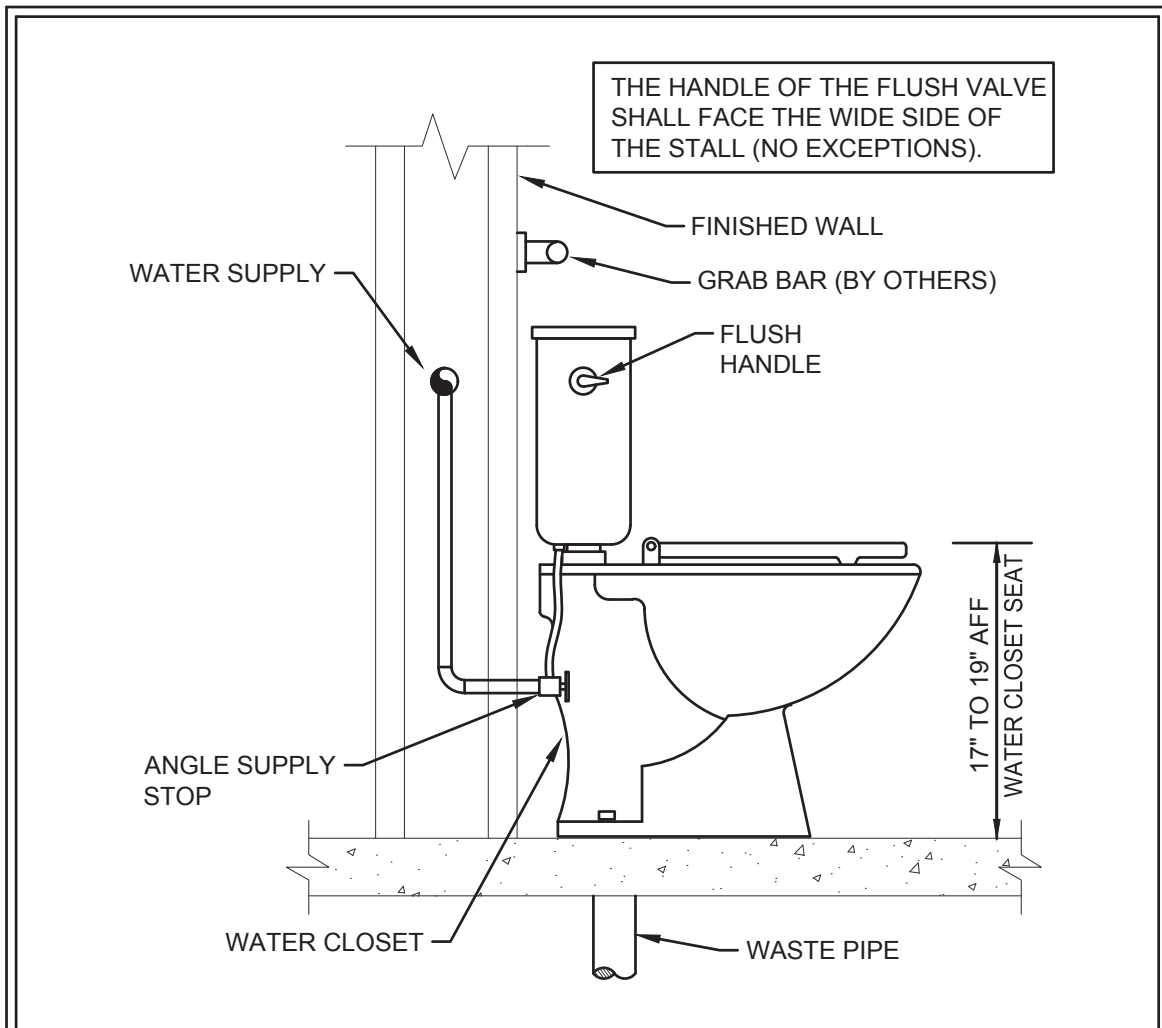

5

WATER CLOSET DETAIL


SCALE: NONE

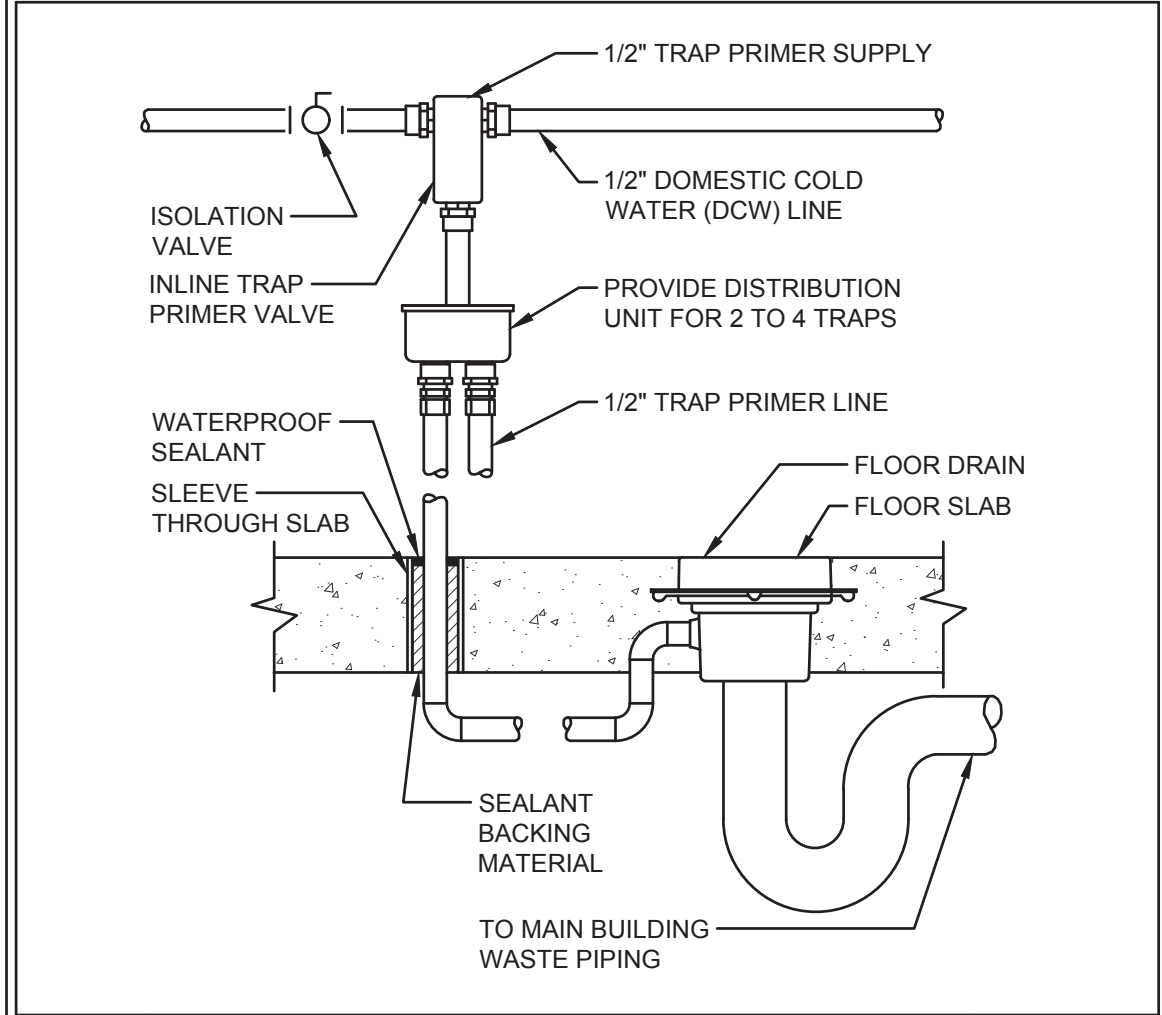

6

TRAP PRIMER DETAIL


SCALE: NONE

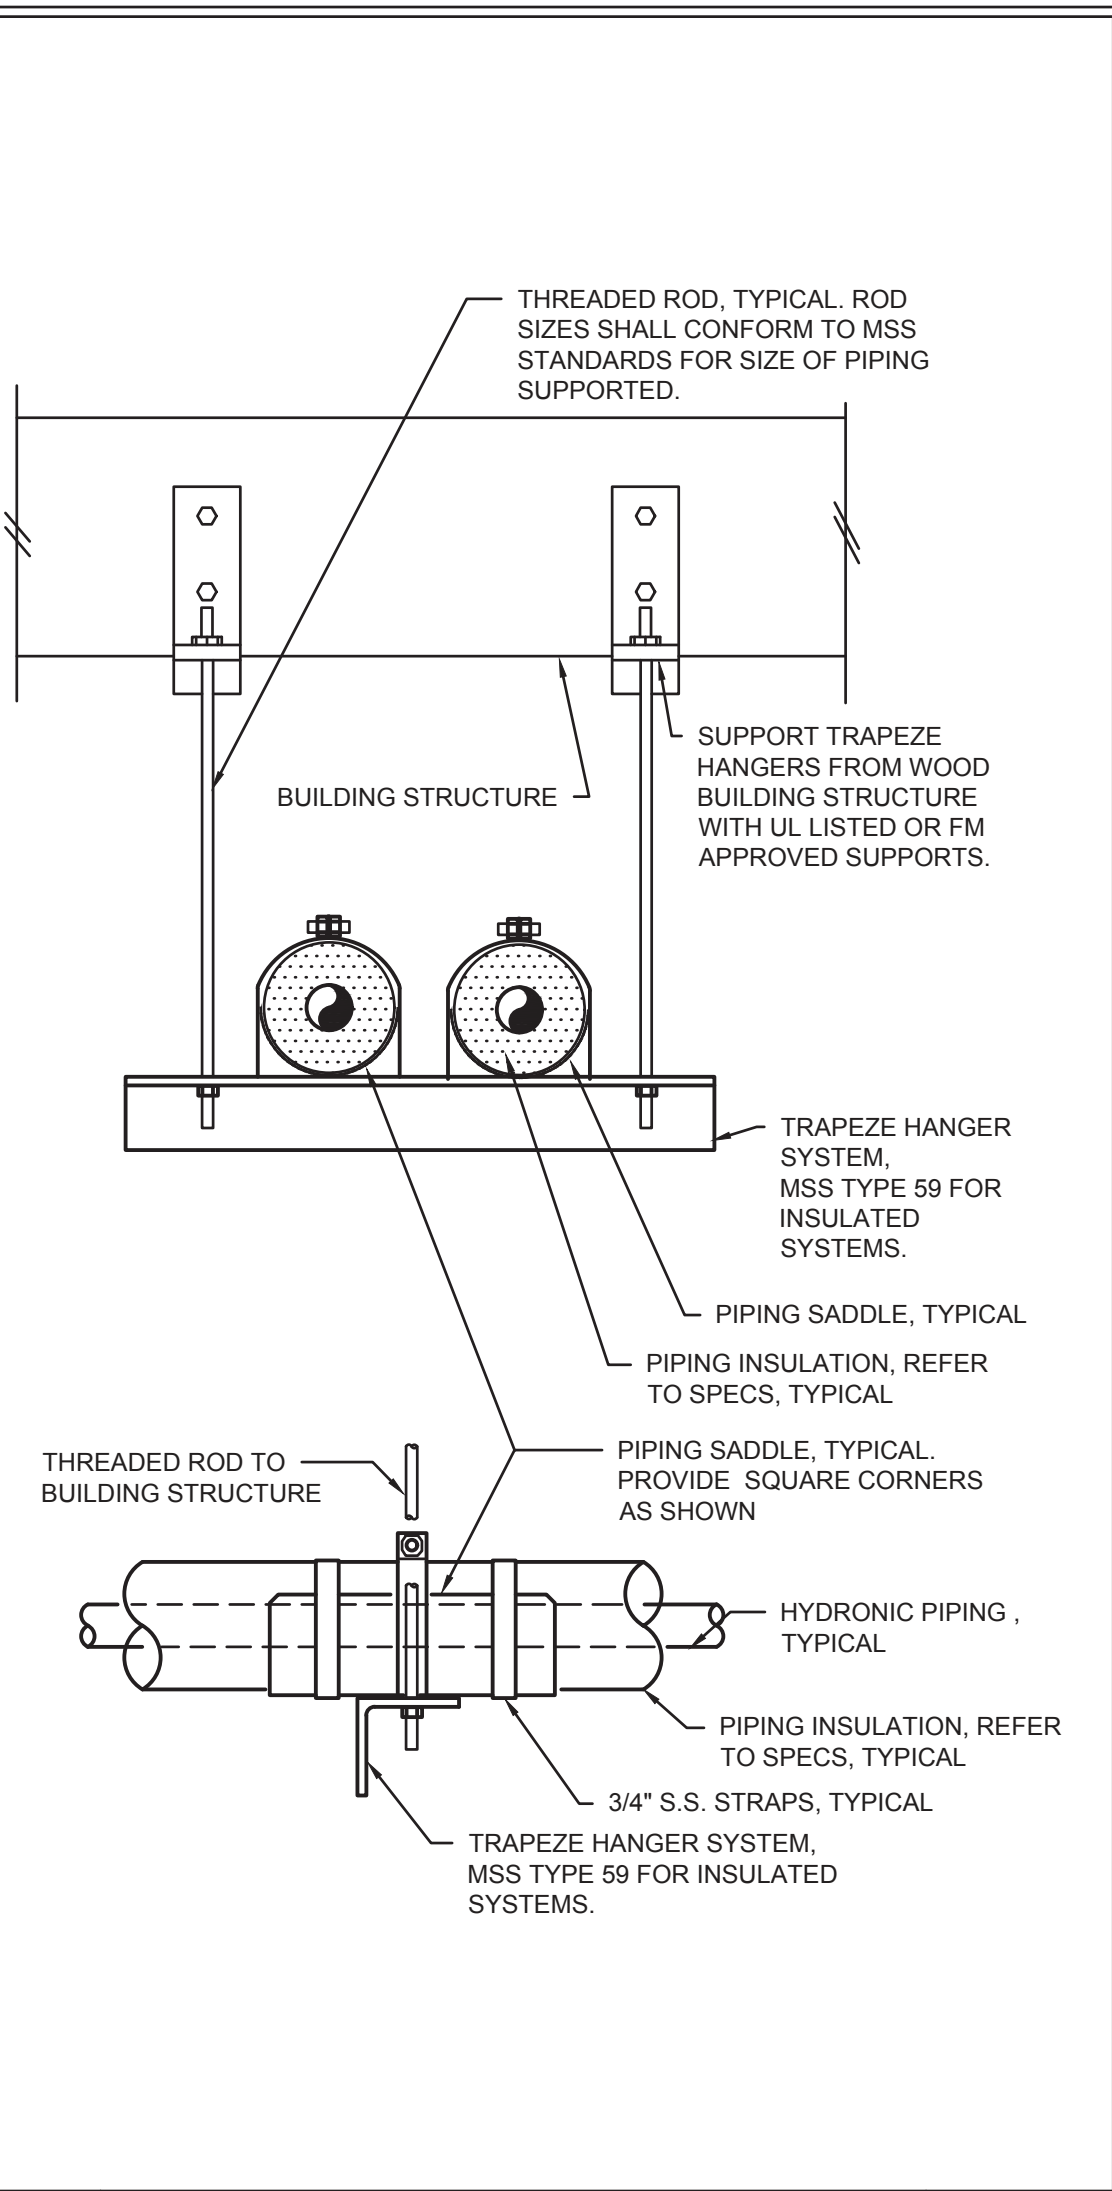

3

HORIZONTAL PIPING SUPPORT FROM WOOD DETAIL


SCALE: NONE

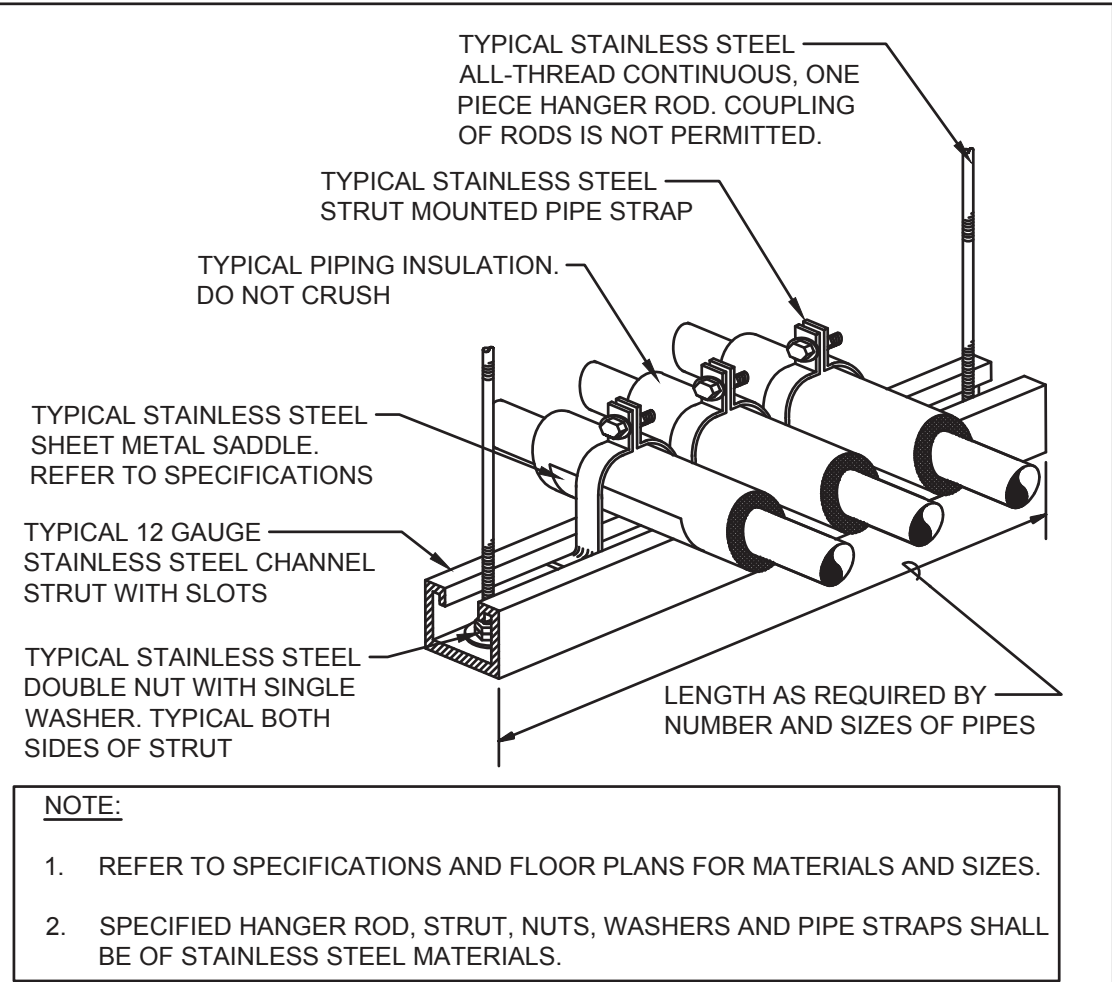

4

TRAPEZE HANGER DETAIL

SCALE: NONE

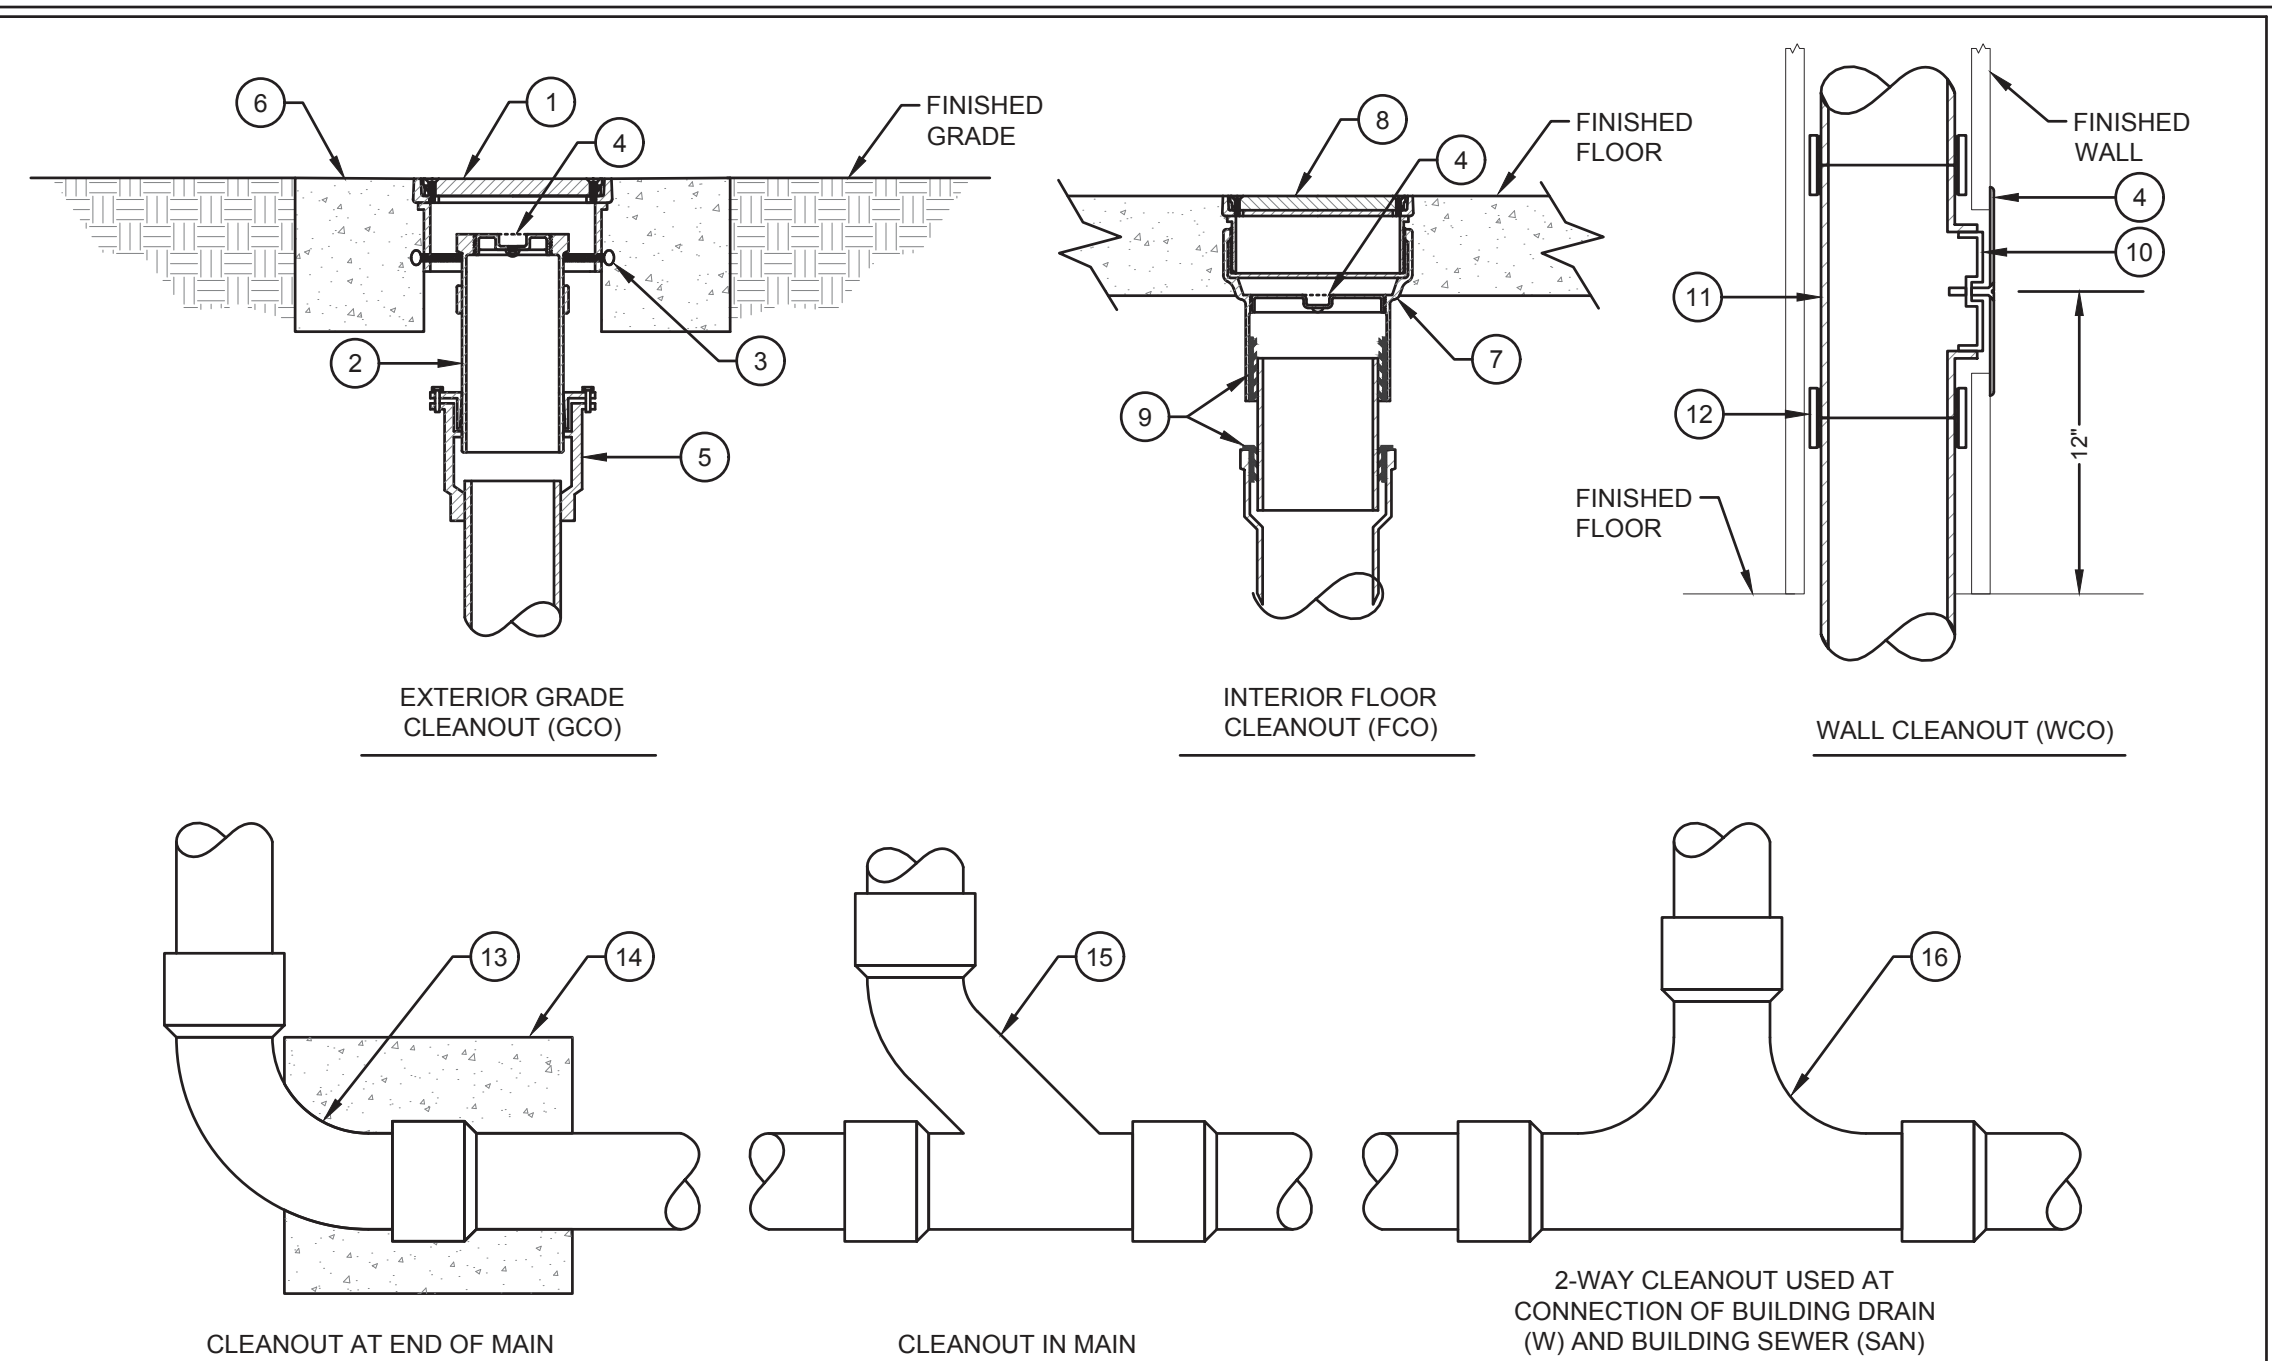


DETAIL KEY NOTES:

1	CAST IRON HOUSING WITH NICKEL BRONZE, ROUND, SECURED, SCORIATED LIGHT-DUTY COVER AND THUMB SCREWS.	9	PUSH-ON NEOPRENE RUBBER COMPRESSION GASKET.
2	CAST IRON CLEANOUT HOUSING.	10	STAINLESS STEEL ROUND WALL ACCESS COVER.
3	ADJUSTABLE THUMB SCREWS.	11	CLEANOUT TEE.
4	TAPERED THREAD, RECESSED HEAD, BRONZE CLEANOUT PLUG.	12	NO-HUB COUPLING (FOR ABOVE GROUND APPLICATION ONLY).
5	EXPANSION JOINT.	13	LONG SWEEP ELBOW.
6	18"x18" SQUARE CONCRETE PAD A MINIMUM OF 4" THICK.	14	12" x 12" x 12" CONCRETE THRUST BLOCK.
7	2 PIECE CAST IRON CLEANOUT WITH ADJUSTABLE HEAD.	15	COMBINATION WYE AND EIGHTH BEND FITTING.
8	NICKEL BRONZE, ROUND, SECURED, SCORIATED LIGHT-DUTY COVER.	16	TWO-WAY CLEANOUT FITTING.

1

CLEANOUT DETAILS

SCALE: NONE

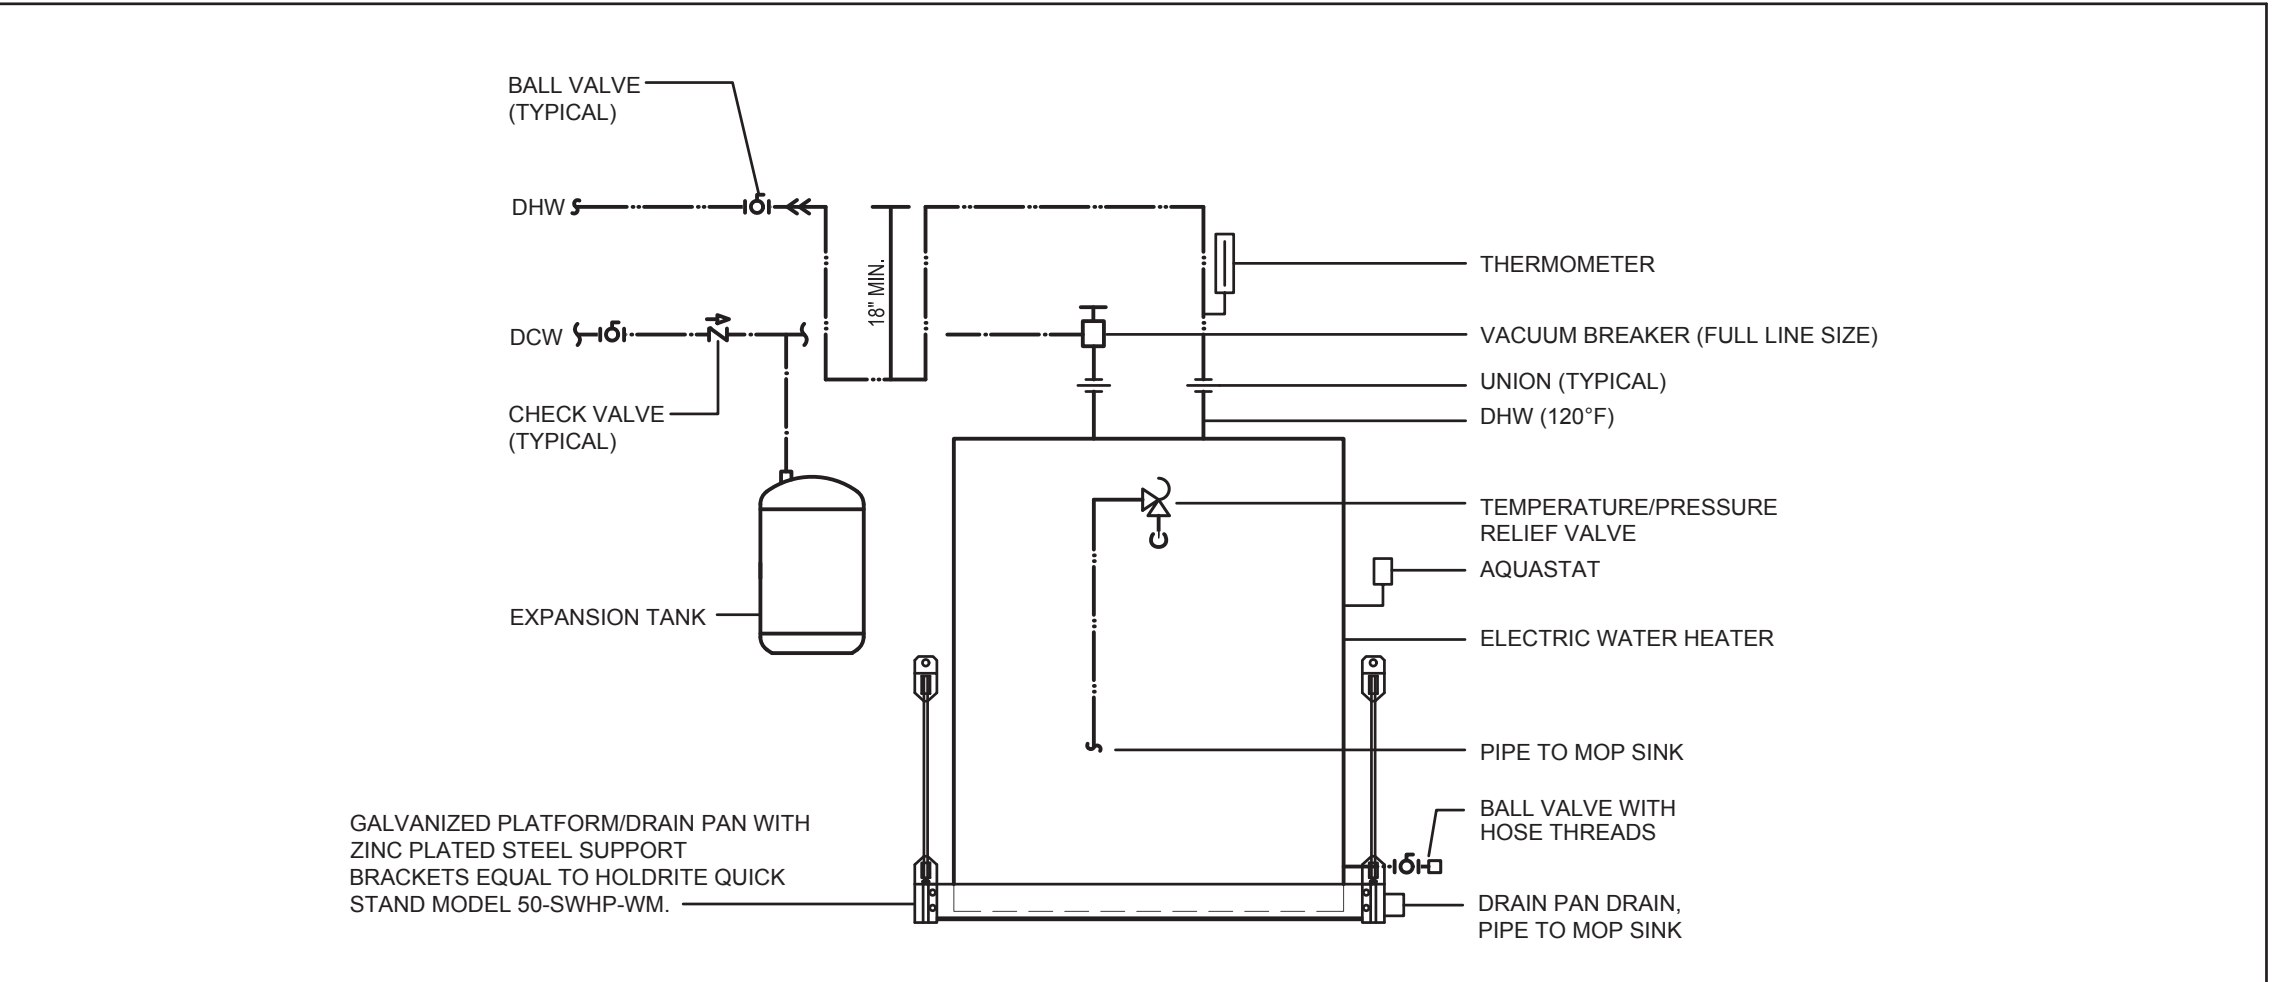

2

WALL HUNG WATER HEATER DETAIL (EWH-1)

SCALE: NONE

THIS ITEM HAS BEEN ELECTRONICALLY SIGNED AND SEALED BY THE ENGINEER INDICATED HEREIN WITH THE DATE AS INDICATED IN THE TIME STAMP. URBAN AREA CODE. PRINTED COPIES OF THIS DOCUMENT ARE NOT CONSIDERED SIGNED AND SEALED AND THE SIGN AUTHENTICATION CODE MUST BE VERIFIED ON ANY ELECTRONIC COPIES.

DESIGNER : TKE
DRAWN BY: TKE
REVIEWED BY: WHI

ISSUE DATE: 28 MARCH 2023
COMP. FILE NO.: 18080
STATE PROJECT NO.: 6183C3

Consultant : TOMAHAWK ENGINEERING & CONSULTING, INC.
1940 Buford Blvd. - Tallahassee, FL 32302
Phone: 850-402-3040, Fax: 850-402-9699
Certificate of Authorization #: 29709
Tallahassee Project #: 22053

MICHAEL BOYLE
L. LICENSE
No. 76983
STATE OF
FLORIDA
EXPIRES
12-28-25
PROFESSIONAL ENGINEER

ICHETUCKNEE SPRINGS STATE PARK
12087 SOUTHWEST U.S. 27, FORT WHITE, FL 32038

DETAILS & SCHEDULES - PLUMBING

PROJECT TITLE
ICHETUCKNEE SPRINGS STATE PARK
REPLACE RESTROOM

SHEET NO.

P501


ELECTRICAL SYMBOL LEGEND	
SYMBOL	DESCRIPTION
GENERAL	
	CONCEALED RACEWAY AND BRANCH CIRCUIT WIRING SYSTEM.
	HOMERUN. LETTER INDICATES PANEL, NUMBER INDICATES CIRCUIT. 2-12 AWG, 12 G, 1/2" C UNLESS OTHERWISE NOTED.
POWER & DEVICE	
	LIGHTING PANEL BOARD. 72" ABOVE FLOOR TO TOP OF PANEL.
	DISCONNECT SWITCH, TYPE AS INDICATED. MOUNT WITHIN SITE OF UNIT. 42" ABOVE FLOOR TO TOP.
	EQUIPMENT CONNECTION TYPE AS INDICATED OR INDICATED BY EQUIPMENT MANUFACTURER.
	MOTOR CONNECTION, TYPE AS INDICATED.
	NORMAL BRANCH DUPLEX CONVENIENCE OUTLET. 18" AF TO BOTTOM UNLESS OTHERWISE NOTED.
	NORMAL BRANCH DUPLEX CONVENIENCE OUTLETS IN COMMON BOX ABOVE COUNTER 4" ABOVE BACK SPLASH TO CENTERLINE UNLESS OTHERWISE NOTED. GFI
	SURFACE MOUNTED NORMAL BRANCH GFI AND WETHER PROOF DUPLEX CONVENIENCE OUTLET. 18" AF TO BOTTOM UNLESS OTHERWISE NOTED.
LIGHTING	
	4ft. NORMAL BRANCH SURFACE LED FIXTURE WITH BATTERY BACKUP INDICATED TO SCALE LOWER CASE LETTER INDICATES SWITCH LEG
	WALL MOUNTED LIGHTING FIXTURE. HEIGHT AS INDICATED.

ABBREVIATIONS	
ABBREVIATION	DESCRIPTION
A	AMPERES
AF	ABOVE FINISHED FLOOR
AF	AMP FRAME
AFC	AVAILABLE FAULT CURRENT
AG	ABOVE GRADE
AIC	AMP INTERRUPTING CAPACITY
AWG	AMERICAN WIRE GAGE
BKR	BREAKER
C	CONDUIT
DCO	DUPLEX CONVENIENCE OUTLET
EF	EXHAUST FAN
FLA	FULL LOAD AMPERES
GND OR G	GROUND
GFI	GROUND FAULT CIRCUIT INTERRUPTER
HP	HORSE POWER
IN	INCHES
LTS	LIGHTS
MLO	MAIN LUGS ONLY
MOCP	MAXIMUM OVER CURRENT PROTECTION
PH OR Ø	PHASE
PNL	PANEL
TR	TAMPER RESISTANT
V	VOLTS
VA	VOLT AMPS
W	WATTS
W	WIRE
(X)	EXISTING TO REMAIN
XFMR	TRANSFORMER


ELECTRICAL SPECIFICATIONS	
	DIVISION 16 - ELECTRICAL
	16010 BASIC ELECTRICAL REQUIREMENTS
A	ALL WORK AND EQUIPMENT UNDER THIS DIVISION SHALL BE IN STRICT COMPLIANCE WITH THE CODES, STANDARDS AND PRACTICES LISTED HEREIN, AND THEIR RESPECTIVE DATES ARE FURNISHED AS THE MINIMUM LATEST REQUIREMENTS.
1	STATE OF FLORIDA
2	LIFE SAFETY CODE - NFPA 101 (2018)
3	UNDERWRITERS LABORATORIES, INC. PUBLICATIONS
4	NATIONAL FIRE PROTECTION ASSOCIATION (NFPA)
5	AMERICAN NATIONAL STANDARDS INSTITUTE (ANSI)
6	NATIONAL ELECTRICAL CODE - NFPA 70 (2017)
7	NATIONAL ELECTRICAL MANUFACTURER'S ASSOCIATION (NEMA)
8	NATIONAL FIRE PROTECTION ASSOCIATION 72 (2016)
9	THE STATE FIRE PREVENTION CODE, 4A60.
10	BUILDING CODE: FLORIDA BUILDING CODE (2020), 7TH EDITION
B	SCOPE OF WORK: THE WORK PROVIDED UNDER THIS DIVISION SHALL INCLUDE ALL LABOR, MATERIALS, PERMITS, INSPECTIONS AND REINSPECTION FEES, TOOLS, EQUIPMENT, TRANSPORTATION, INSURANCE, TEMPORARY PROTECTION, TEMPORARY LIGHTING, SUPERVISION AND INCIDENTAL ITEMS ESSENTIAL FOR PROPER INSTALLATION AND OPERATION, EVEN THOUGH NOT SPECIFICALLY MENTIONED OR INDICATED BUT WHICH ARE USUALLY PROVIDED OR ARE ESSENTIAL FOR PROPER INSTALLATION AND OPERATION OF ALL ELECTRICAL SYSTEMS AS INDICATED IN CONTRACT DOCUMENTS.
C	NOTICES: GIVE ALL NOTICES, FILE ALL PLANS, PAY ALL FEES, OBTAIN ALL PERMITS AND APPROVALS FROM AUTHORITIES HAVING JURISDICTION. INCLUDE ALL FEES IN THE BID PRICE.
D	INTERPRETATION OF DRAWINGS:
1	THE DRAWINGS ARE DIAGRAMMATIC AND ARE NOT INTENDED TO SHOW EXACT LOCATIONS OF CONDUIT RUNS, OUTLET BOXES, JUNCTION BOXES, PULL BOXES, ETC. THE LOCATIONS OF EQUIPMENT, APPLIANCES, FIXTURES, CONDUITS, OUTLETS, BOXES AND SIMILAR DEVICES SHOWN ON THE DRAWINGS ARE APPROXIMATE ONLY. EXACT LOCATIONS SHALL BE AS ACCEPTED BY THE ENGINEER DURING CONSTRUCTION. OBTAIN IN THE FIELD ALL INFORMATION RELEVANT TO THE PLACING OF ELECTRICAL WORK AND IN CASE OF INTERFERENCE WITH OTHER WORK, PROCEED AS DIRECTED BY THE ENGINEER AND PROVIDE ALL LABOR AND MATERIALS NECESSARY TO COMPLETE THE WORK IN AN ACCEPTABLE MANNER.
2	DISCREPANCIES: NOTIFY ARCHITECT/ENGINEER OF ANY DISCREPANCIES FOUND DURING CONSTRUCTION OF THE PROJECT AND DO NOT PROCEED WITH THAT PORTION OF THE PROJECT, UNTIL A WRITTEN DEFINITIVE STATEMENT IS RECEIVED PROVIDING CLEAR DIRECTION. IF A CONFLICT EXISTS BETWEEN THE CONTRACT DOCUMENTS AND ANY APPLICABLE CODE OR STANDARD, THE MOST STRINGENT REQUIREMENT SHALL BE INCLUDED FOR THIS PROJECT. THE ENGINEER SHALL MAKE THE DECISION REGARDING QUESTIONABLE AREAS OF CONFLICT.
E	INVESTIGATION ON SITE:
1	GENERAL: BEFORE COMMENCING THE WORK, VERIFY EXISTING CONDITIONS AT THE PREMISES INCLUDING, BUT NOT LIMITED TO, EXISTING STRUCTURAL FRAME, LOCATION AND ALL DIMENSIONS; EXISTING OPENINGS AND CHARACTERISTICS; EXISTING WALL AND PARTITION LOCATIONS, CHARACTERISTICS AND RELATIONSHIP TO EACH OTHER; EXISTING MECHANICAL AND ELECTRICAL WORK, EQUIPMENT TYPE, AND SHALL EXAMINE ALL ADJOINING WORK ON WHICH HIS WORK IF ANYWAY DEPENDENT FOR ITS PERFECT EFFICIENCY ACCORDING TO THE INTENT OF THE CONTRACT DOCUMENTS.
2	POWER OUTAGE: SPECIAL ATTENTION IS CALLED TO THE FACT THAT WORK INVOLVED IS IN CONNECTION WITH EXISTING BUILDINGS WHICH REMAIN IN OPERATION WHILE WORK IS BEING PERFORMED. WORK MUST BE DONE IN ACCORDANCE WITH THE PRIORITY SCHEDULE. SCHEDULE WORK FOR A MINIMUM OUTAGE TO OWNER. REQUEST WRITTEN PERMISSION AND RECEIVE WRITTEN ACCEPTANCE FROM THE OWNER NO LATER THAN 24 HOURS IN ADVANCE OF ALL POWER AND COMMUNICATION SHUT-DOWNS. PERFORM WORK REQUIRED AT OTHER THAN STANDARD WORKING HOURS WHERE OUTAGES CANNOT BE ACCEPTED BY OWNER DURING REGULAR WORKING HOURS. PROTECT EXISTING BUILDINGS AND EQUIPMENT DURING CONSTRUCTION.
3	SPECIAL CONSIDERATIONS: SPECIAL ATTENTION IS CALLED TO THE FACT THAT THERE WILL BE PIPING, FIXTURES OR OTHER ITEMS IN THE EXISTING BUILDING WHICH MUST BE REMOVED OR RELOCATED IN ORDER TO PERFORM THE ALTERATION WORK. BID SHALL INCLUDE ALL REMOVAL AND RELOCATION REQUIRED FOR COMPLETION OF THE ALTERATIONS AND THE NEW CONSTRUCTION.
4	OWNER'S SALVAGE: THE OWNER RESERVES THE RIGHT TO INSPECT THE MATERIAL SCHEDULED FOR REMOVAL AND SALVAGE ANY ITEMS HE DEEMS USABLE AS SPARE PARTS.
F	EXISTING CONDITIONS:
1	SUPPORT: ALL EXISTING CONDUIT AND CABLES WITHIN THE AREA OF RENOVATION SHALL BE PROVIDED WITH PROPER SUPPORTS AS SPECIFIED FOR NEW WORK IN OTHER SECTIONS OF THIS SPECIFICATION.

ELECTRICAL SPECIFICATIONS	
2	INSTALLATION: ALL EXISTING ELECTRICAL WHICH IS DESIGNATED FOR REWORKING OR REQUIRES RELOCATION, REPAIR OR ADJUSTMENT SHALL CONFORM TO ALL APPLICABLE CODES AND SHALL BE TREATED AS NEW WORK COMPLYING TO ALL SECTIONS OF THIS SPECIFICATION.
3	VIOLATIONS: WHERE EXISTING CONDITIONS ARE DISCOVERED WHICH ARE NOT IN COMPLIANCE WITH THE CODES AND STANDARDS, THE CONTRACTOR SHALL SUBMIT PROPER DOCUMENTATION TO THE ARCHITECT FOR CLARIFICATION AND CORRECTIVE WORK DIRECTION. EXISTING CONDITIONS SHALL NOT REMAIN WHICH WILL CREATE A DISAPPROVAL OF THE RENOVATED AREA.
4	PATCHING: ALL EXISTING CONDUIT AND CABLE PENETRATIONS SHALL BE PROPERLY FIRE TREATED PER CODE AND SPECIFICATION REQUIREMENTS. THE CONTRACTOR SHALL THOROUGHLY INSPECT ALL EXISTING LOCATIONS AND INCLUDE THE COST OF PATCHING AND REPAIR IN HIS PROPOSED CONSTRUCTION COST.
G	ALL MATERIALS SHALL BE NEW, FREE FROM DEFECTS AND SHALL BE EITHER U.L. LABELED, U.L. LISTED OR BEAR THE SEAL OF A NATIONALLY RECOGNIZED ELECTRICAL TESTING LABORATORY.
H	SHOP DRAWINGS ARE REQUIRED FOR ALL MATERIALS AND EQUIPMENT EXCLUDING CONDUIT, WIRE, AND WIRING DEVICES.
I	ALL EQUIPMENT SHALL BE FIRMLY MOUNTED USING APPROVED HANGERS ATTACHED TO STRUCTURAL PORTIONS OF THE BUILDING. SUPPORTING WITH TIE WIRE IS PROHIBITED. LIGHT FIXTURES RECESSED IN CEILINGS SHALL BE SUPPORTED FROM THE BUILDING STRUCTURE INDEPENDENT OF THE CEILING SYSTEM.
J	TEMPORARY LIGHT AND POWER SHALL BE PROVIDED AS REQUIRED.
	16030 ELECTRICAL IDENTIFICATION
A	LANGUAGE ALL IDENTIFICATION SHALL BE IN ENGLISH.
B	EQUIPMENT SYSTEM MARKERS SHALL BE ENGRAVED PLASTIC, LAMINATE NAMEPLATES AND SHALL BE ADHESIVE OR PRE-TENSIONED SNAP ON COLOR CODED, SYSTEM MARKING MATERIALS.
C	CONDUIT, RACEWAYS, BOXES, ETC. SHALL BE SPOT PAINTED. CONDUIT SHALL BE IDENTIFIED WITHIN 6 INCHES OF THE BOX OR ENCLOSURE. THE ENTIRE BOX COVER PLATE SHALL BE PAINTED.
D	USE FOLLOWING COLORS FOR COLOR BANDS AND FOR COLOR CODING;
	SYSTEM - COLOR
1	NORMAL POWER - BLUE
E	CABLE AND CONDUCTOR IDENTIFICATION WILL BE AS PER NFPA 70.
	16110 BASIC MATERIALS AND METHODS
A	RACEWAYS AND FITTINGS:
1	ALL WIRING SHALL BE INSTALLED IN APPROPRIATE RACEWAY SYSTEMS OF PVC SCHEDULE 80.
2	FLEXIBLE CONDUIT SHALL BE USE ONLY FOR FIXTURE WHIPS AND SHALL NOT EXCEED 72".
3	ALL CONDUIT SHALL HAVE AN INSULATED COPPER EQUIPMENT GROUNDING CONDUCTOR THROUGHOUT THE ENTIRE LENGTH OF THE CIRCUIT WITHIN THE CONDUIT.
	16120 WIRES AND CABLES
A	ALL BRANCH CIRCUITS AND FEEDERS SHALL BE COPPER WITH THHN OR THWN INSULATION. MINIMUM SIZE #12 AWG. SIZES #10 AWG AND SMALLER SHALL BE SOLID.
B	COLOR CODING SHALL COMPLY WITH THE NATIONAL ELECTRIC CODE, 2014 EDITION SPECIFICALLY. PHASE CONDUCTORS OF EACH VOLTAGE SYSTEM MUST BE OF A DIFFERENT COLOR. NEUTRALS SHALL BE WHITE FOR 120/208 AND GRAY FOR 277/480. EQUIPMENT GROUNDING CONDUCTORS SHALL BE GREEN INSULATED.
C	ALL SINGLE PHASE CIRCUITS SHALL HAVE DEDICATED NEUTRAL CONDUCTORS. NO NEUTRAL CONDUCTORS SHALL BE SHARED.
	16130 OUTLET BOXES
A	OUTLET BOXES SHALL BE THERMOPLASTIC. SECTIONAL BOXES ARE NOT ACCEPTABLE. BOXES SHALL BE 4" SQUARE AND 1-1/2" DEEP GENERALLY. LARGER BOXES SHALL BE USED AS REQUIRED BY CODE.
	16140 WIRING DEVICES
A	ALL RECEPTACLES SHALL BE 20 AMP, 125 VOLT GROUNDING TYPE, (SPECIFICATION GRADE) AND MOUNTED AT 18" AFF.
B	SWITCHES SHALL BE 20 AMP, 125V SILENT TYPE, SPECIFICATION GRADE, AND MOUNTED AT 48" AFF.
C	DEVICE PLATES SHALL BE THERMOPLASTIC COLOR MATCHING DEVICE. DEVICE COLORS SHALL BE SELECTED BY ARCHITECT.
D	APPROVED MANUFACTURERS: HUBBEL, PASS & SEYMOR, LEVITON.
	16500 LIGHTING
1	LIGHTING SHALL BE DESIGNED FOR TYPE OF TASK INVOLVED AND IN GENERAL SHALL UTILIZE 4000-DEGREE K. LED.


LIGHTING FIXTURE SCHEDULE					
TYPE	LAMPS #	LAMPS DESCRIPTION	LUMINAIRE DESCRIPTION	MANUFACTURER	CATALOG #
S1E	NA	LED 2775 LUMENS 25W 4000K >= 80CRI	4'-0" LED VANDAL RESISTANT LIGHT WITH POLYCARBONATE LENS AND UNIVERSAL POWER SUPPLY. PROVIDED WITH 90 MINUTE BATTERY BACKUP.	LUMINAIRE OR EQUIVALENT	VPF4-4FT-NODIM-25W-40K-MVOLT-OP-WHT-EMB310
W1	NA	LED 1970 LUMENS 20W 4000K >= 80CRI	LED WALL MOUNTED VANDAL RESISTANT LIGHT WITH POLYCARBONATE LENS AND UNIVERSAL POWER SUPPLY. *ARCHITECT TO DETERMINE FINISH.	LITHONIA OR EQUIVALENT	DSXW1 LED 10C 530 40K T4M MVOLT VG *

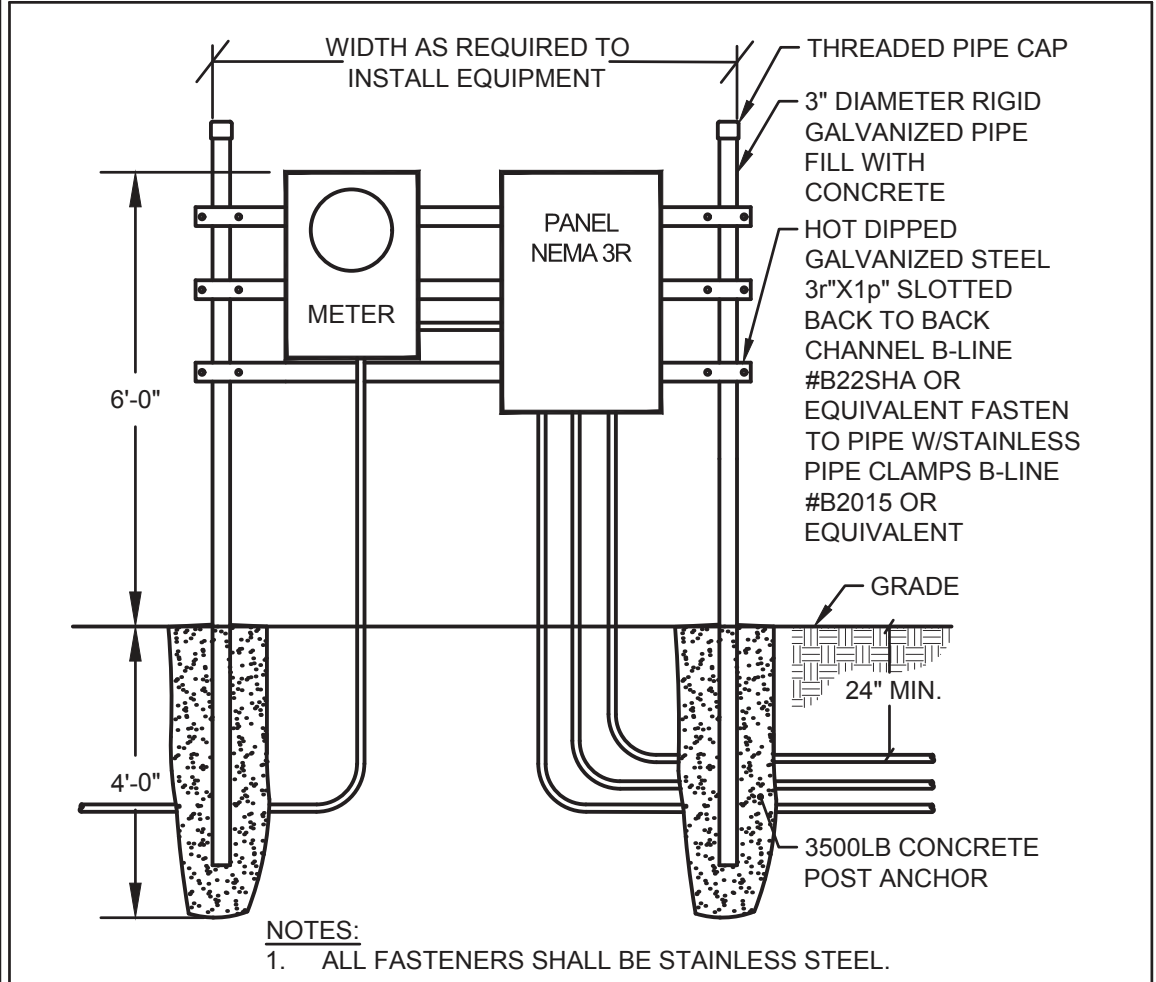

3	UNISTRUT FRAMING DETAIL	SCALE: NONE
---	-------------------------	-------------

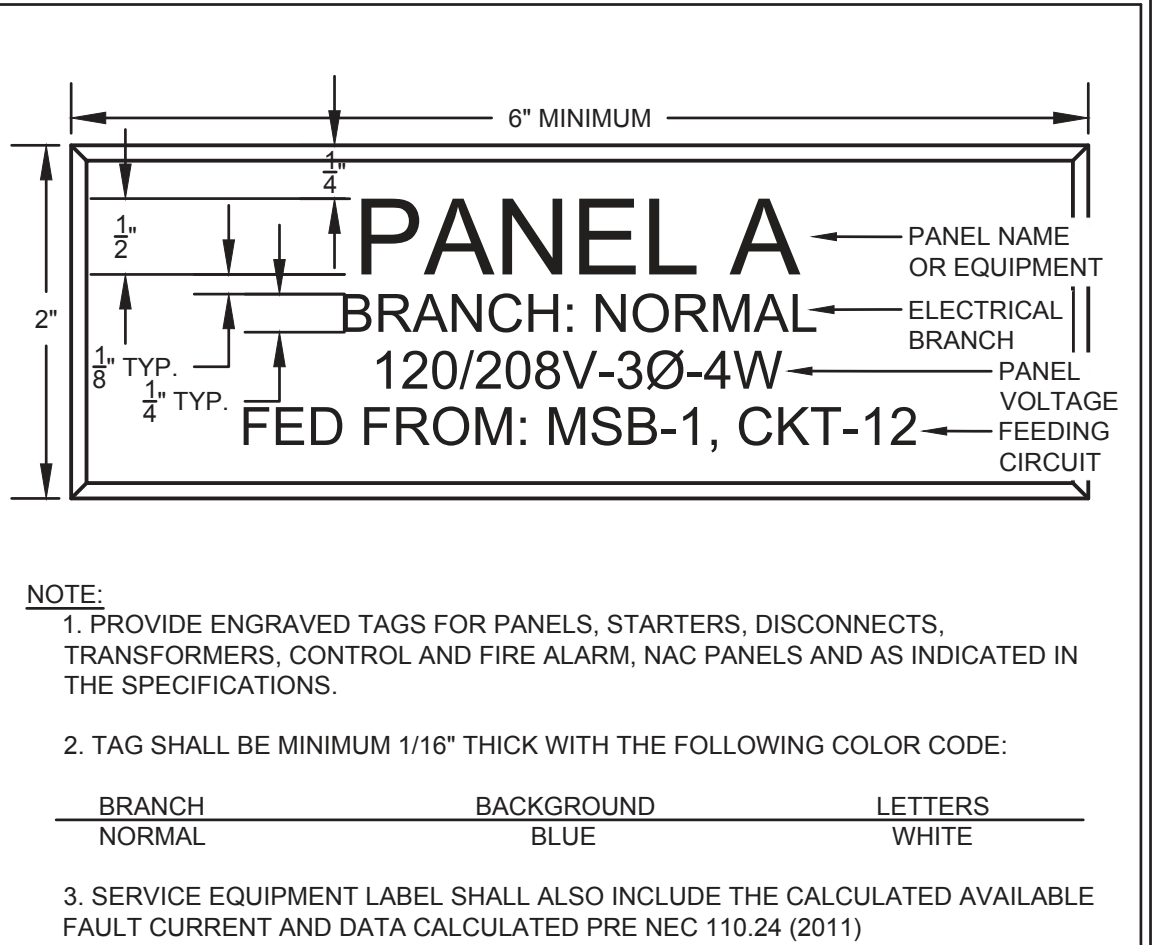

2	NAME PLATE DETAIL	SCALE: NONE
---	-------------------	-------------

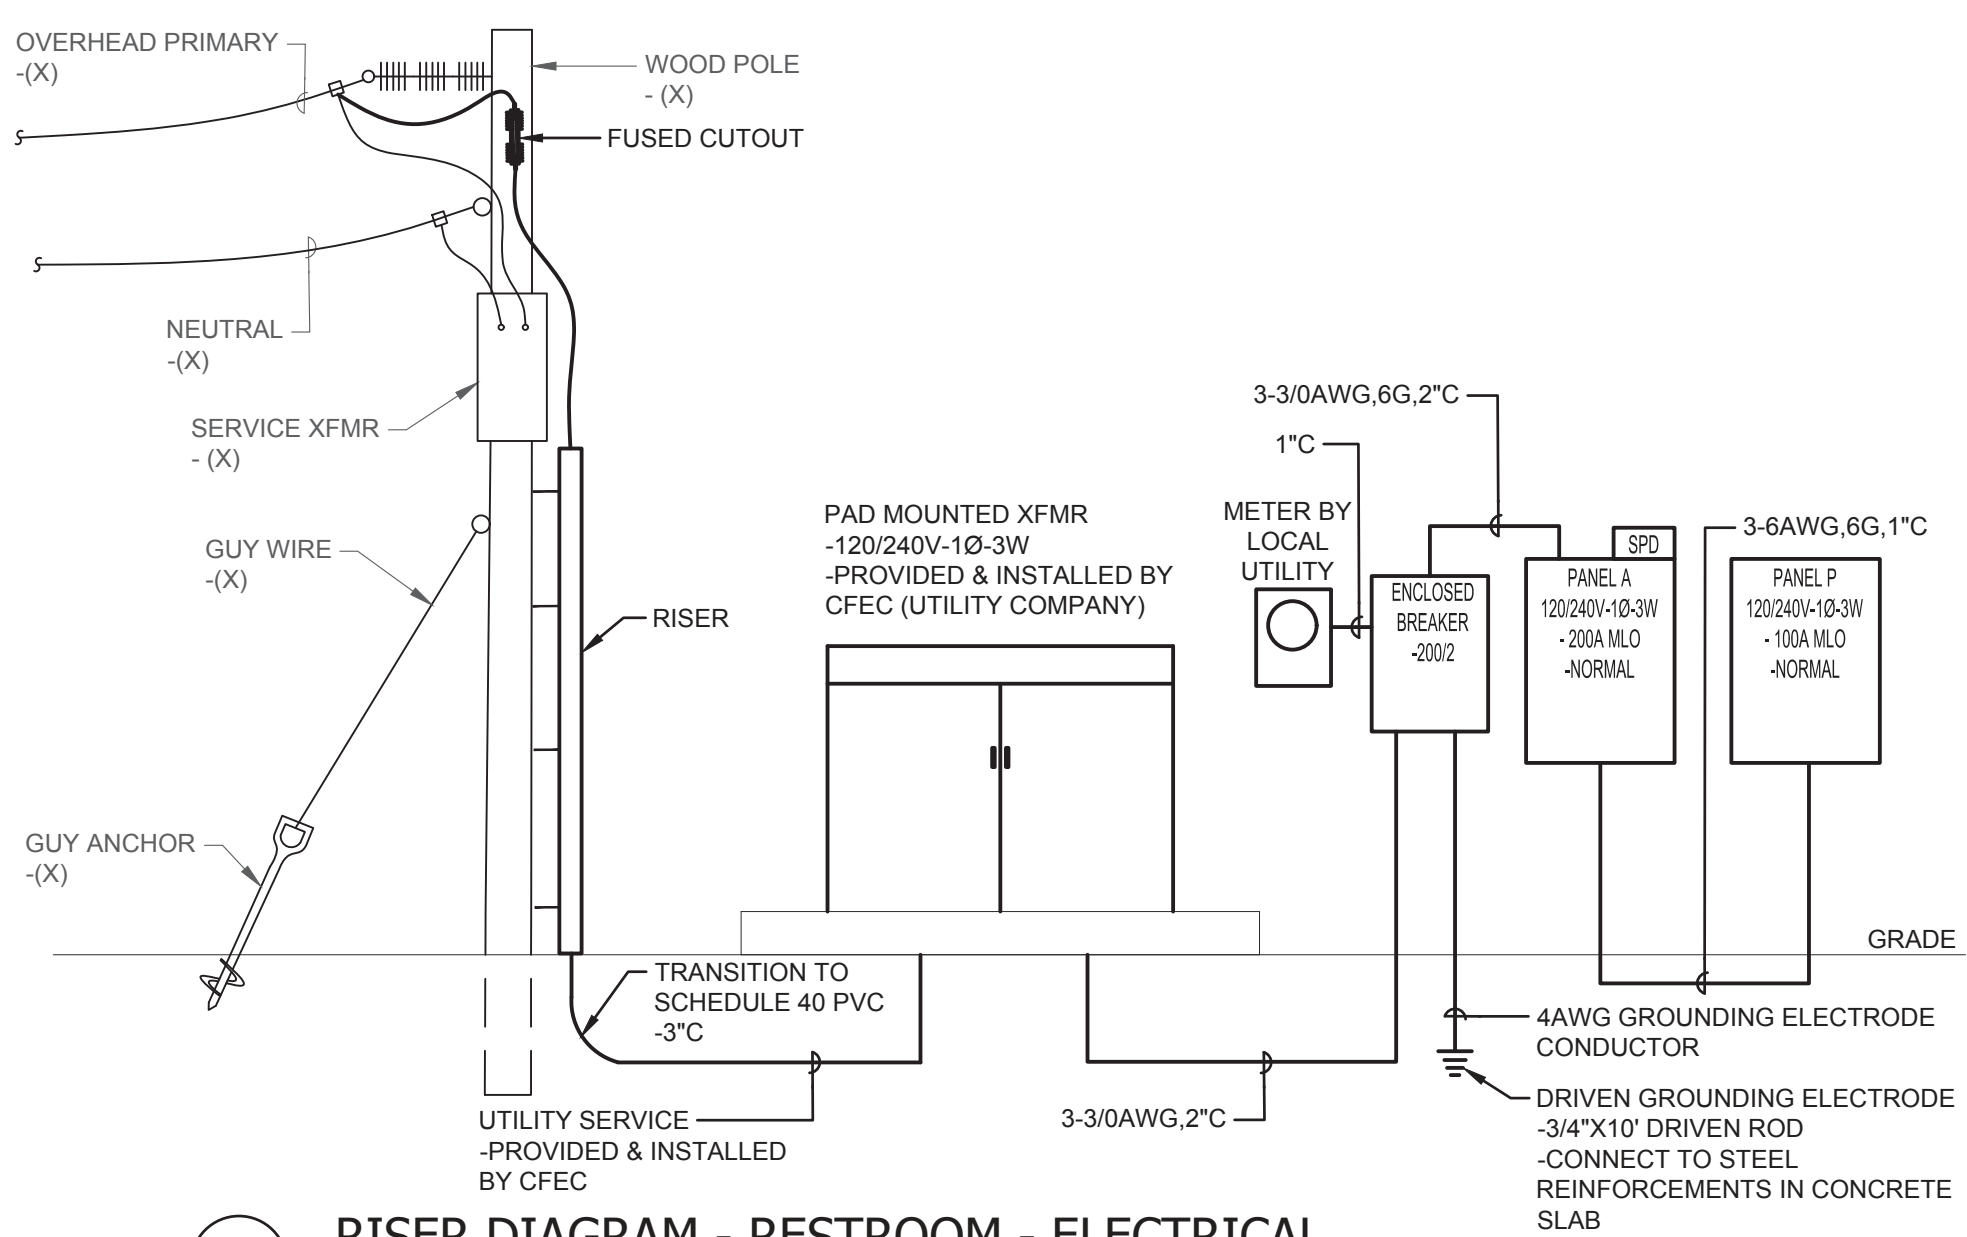

1 RISER DIAGRAM - RESTROOM - ELECTRICAL
SCALE: NONE

THIS ITEM HAS BEEN ELECTRONICALLY SIGNED AND SEALED BY THE ENGINEER INDICATED HEREIN WITH THE DATE AS INDICATED IN THE TIME STAMP. URBAN AREA CODE. PRINTED COPIES OF THIS DOCUMENT ARE NOT CONSIDERED SIGNED AND SEALED AND THE SIGN AUTHENTICATION CODE MUST BE VERIFIED ON ANY ELECTRONIC COPIES.

ISSUE DATE: 28 MARCH 2023
COMP. FILE No.: 16980
STATE PROJECT No.: 61838C

DESIGNER: BCP
DRAWN BY: BCP
REVIEWED BY: RUL
Consultant: TOMAHAWK ENGINEERING & CONSULTING, INC.
1940 Buford Blvd. - Tallahassee, FL 32302
Phone: 850-402-3040, Fax: 850-402-9689
Certificate of Authorization #: 29709
Tallahaw Project #: 22053

28 MARCH 2023
COMP. FILE No.: 16980
STATE PROJECT No.: 61838C

DESIGNER: BCP
DRAWN BY: BCP
REVIEWED BY: RUL
Consultant: TOMAHAWK ENGINEERING & CONSULTING, INC.
1940 Buford Blvd. - Tallahassee, FL 32302
Phone: 850-402-3040, Fax: 850-402-9689
Certificate of Authorization #: 29709
Tallahaw Project #: 22053

28 MARCH 2023
COMP. FILE No.: 16980
STATE PROJECT No.: 61838C


DESIGNER: BCP
DRAWN BY: BCP
REVIEWED BY: RUL
Consultant: TOMAHAWK ENGINEERING & CONSULTING, INC.
1940 Buford Blvd. - Tallahassee, FL 32302
Phone: 850-402-3040, Fax: 850-402-9689
Certificate of Authorization #: 29709
Tallahaw Project #: 22053

ICHELUCKNEE SPRINGS STATE PARK
12087 SOUTHWEST U.S. 271 FORT WHITE, FL 32038


LEGEND & NOTES - ELECTRICAL

ICHELUCKNEE SPRINGS STATE PARK
REPLACE RESTROOM

SHEET NO. E001

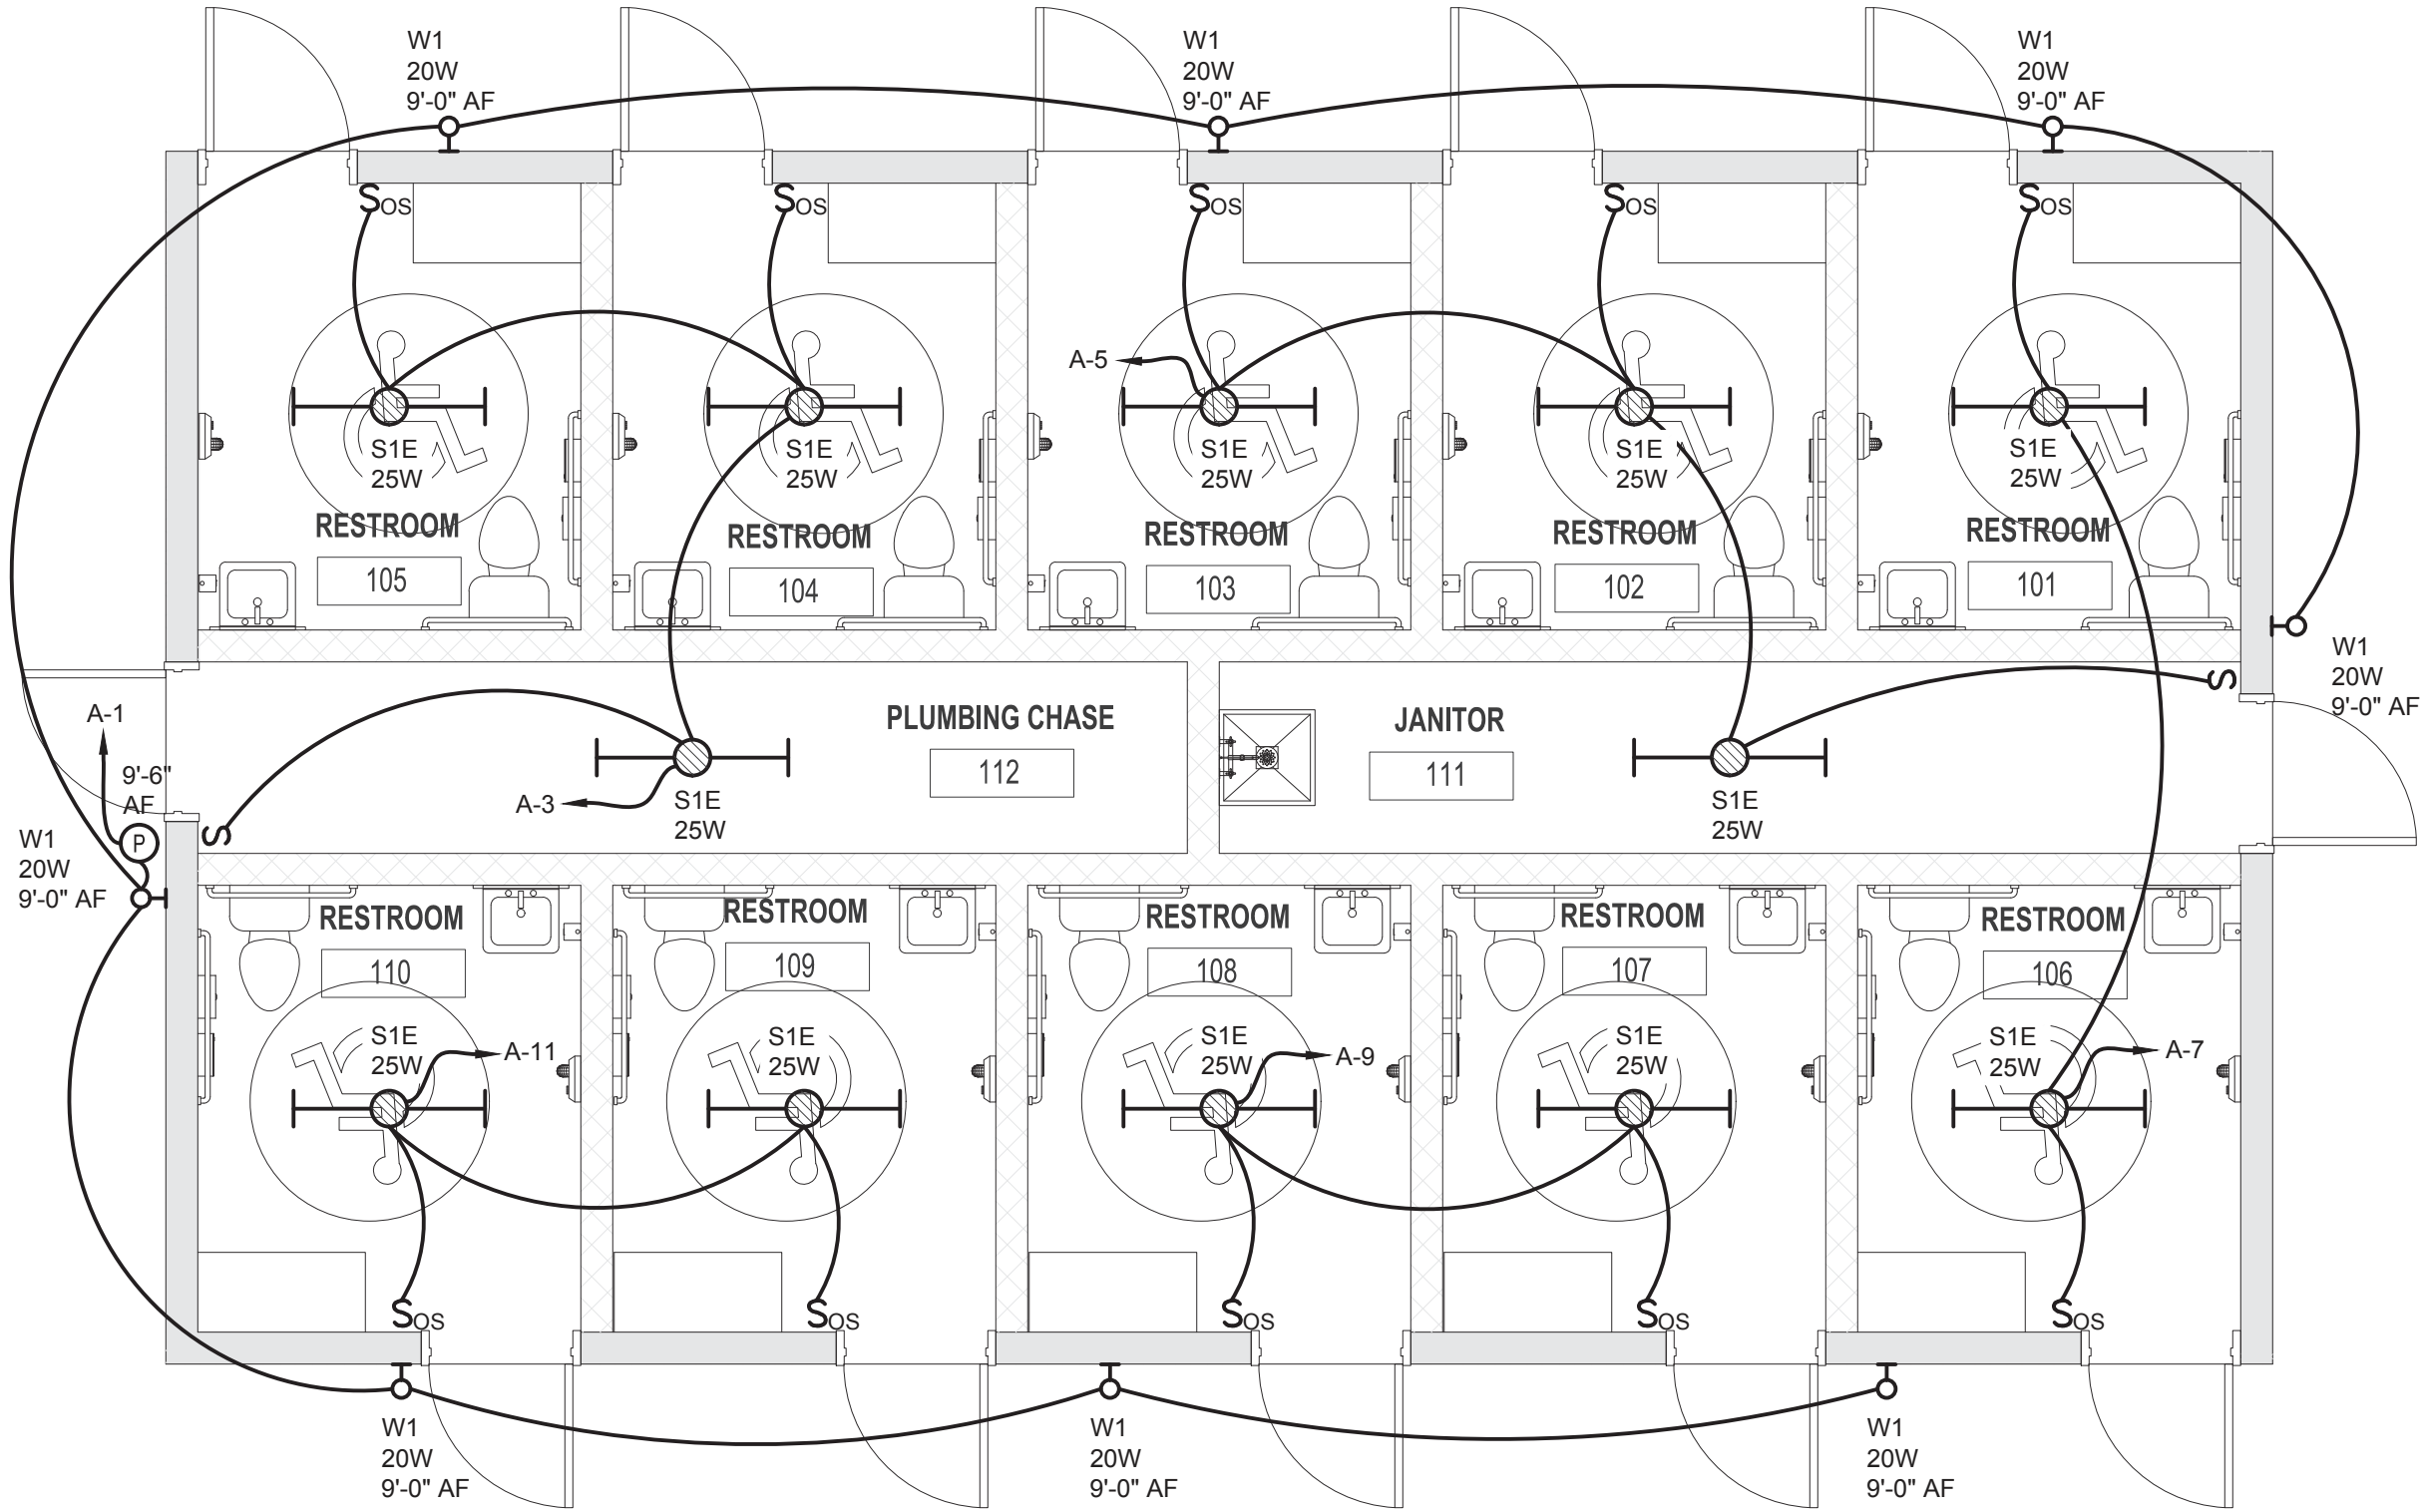

GENERAL SHEET NOTES:	
1	THE ELECTRICAL CONTRACTOR SHALL VISIT THE SITE AND BECOME FAMILIAR WITH THE EXISTING CONDITIONS, ALL OTHER CONTRACT DOCUMENTS, AND SHALL BE RESPONSIBLE FOR THE ELECTRICAL WORK REQUIRED BY THESE DOCUMENTS.
2	OUTLET BOXES SHALL NOT BE MOUNTED BACK TO BACK. OFFSET OUTLET BOXES TO MINIMIZE SOUND TRANSMISSION BETWEEN ROOMS.
3	COORDINATE THE LOCATION OF LIGHTS, ETC. WITH OTHER TRADES. IN GENERAL, LIGHTS, ETC. SHALL BE MOUNTED IN THE CENTER OF A CEILING TILE. REFER TO ARCHITECTURAL REFLECTED CEILING PLAN.
4	CONTRACTOR SHALL PROVIDE STRUCTURAL SUPPORT AS REQUIRED TO INSTALL LIGHTING FIXTURES.
3	COORDINATE OUTLET BOX LOCATIONS WITH FURNITURE, CABINETS, AND EQUIPMENT. REFER TO ARCHITECTURAL ELEVATIONS.
4	COORDINATE SWITCH BOX LOCATIONS WITH FURNITURE, CABINETS, DOORS, SIDE LITES, ETC.. IN GENERAL, SWITCHES SHALL BE ADJACENT TO LATCH SIDE OF DOOR. REFER TO ARCHITECTURAL ELEVATIONS.
5	COORDINATE ROUTING OF CONDUITS WITH OTHER TRADES. CONDUITS SHALL BE RUN PARALLEL AND PERPENDICULAR TO WALLS, CEILINGS, AND FLOORS. PROVIDE JUNCTION AND/OR PULL BOXES AS REQUIRED BY FIELD CONDITIONS.
6	PROVIDE IDENTIFICATION FOR EQUIPMENT, DEVICES & BRANCH CIRCUIT CONDUCTORS AS CALLED FOR IN THE SPECIFICATIONS.
7	REFER TO THE SYMBOLS LIST AND SPECIFICATIONS FOR MOUNTING HEIGHTS OF DEVICES.
8	REFER TO PROJECT SPECIFICATIONS FOR ADDITIONAL REQUIREMENTS, EQUIPMENT SCHEDULES AND DETAILS.
9	NEUTRAL CONDUCTORS SHALL NOT BE SHARED.
10	WHERE THE CONTRACTOR DEVIATES FROM THIS SET OF CONSTRUCTION DOCUMENTS AND RESUBMISSION OF REVISED DRAWINGS IS REQUIRED BY THE PERMITTING OFFICE/OFFICIAL, A MINIMUM CHARGE OF \$750.00 PER AFFECTED DRAWING SHEET WILL BE BILLED TO THE CONTRACTOR. THE REVISED DRAWINGS WILL NOT BE PROVIDED AND/OR SUBMITTED TO THE PERMIT OFFICE UNTIL A PURCHASE ORDER OR SIGNED AGREEMENT IS ISSUED BY THE CONTRACTOR TO THE DESIGN PROFESSIONAL FOR WORK REQUIRED. THIS SHALL NOT APPLY TO UNFORESEEN CONDITIONS OR CHANGES REQUIRED FOR THE PROJECT THAT ARE NOT INITIATED BY THE CONTRACTOR.

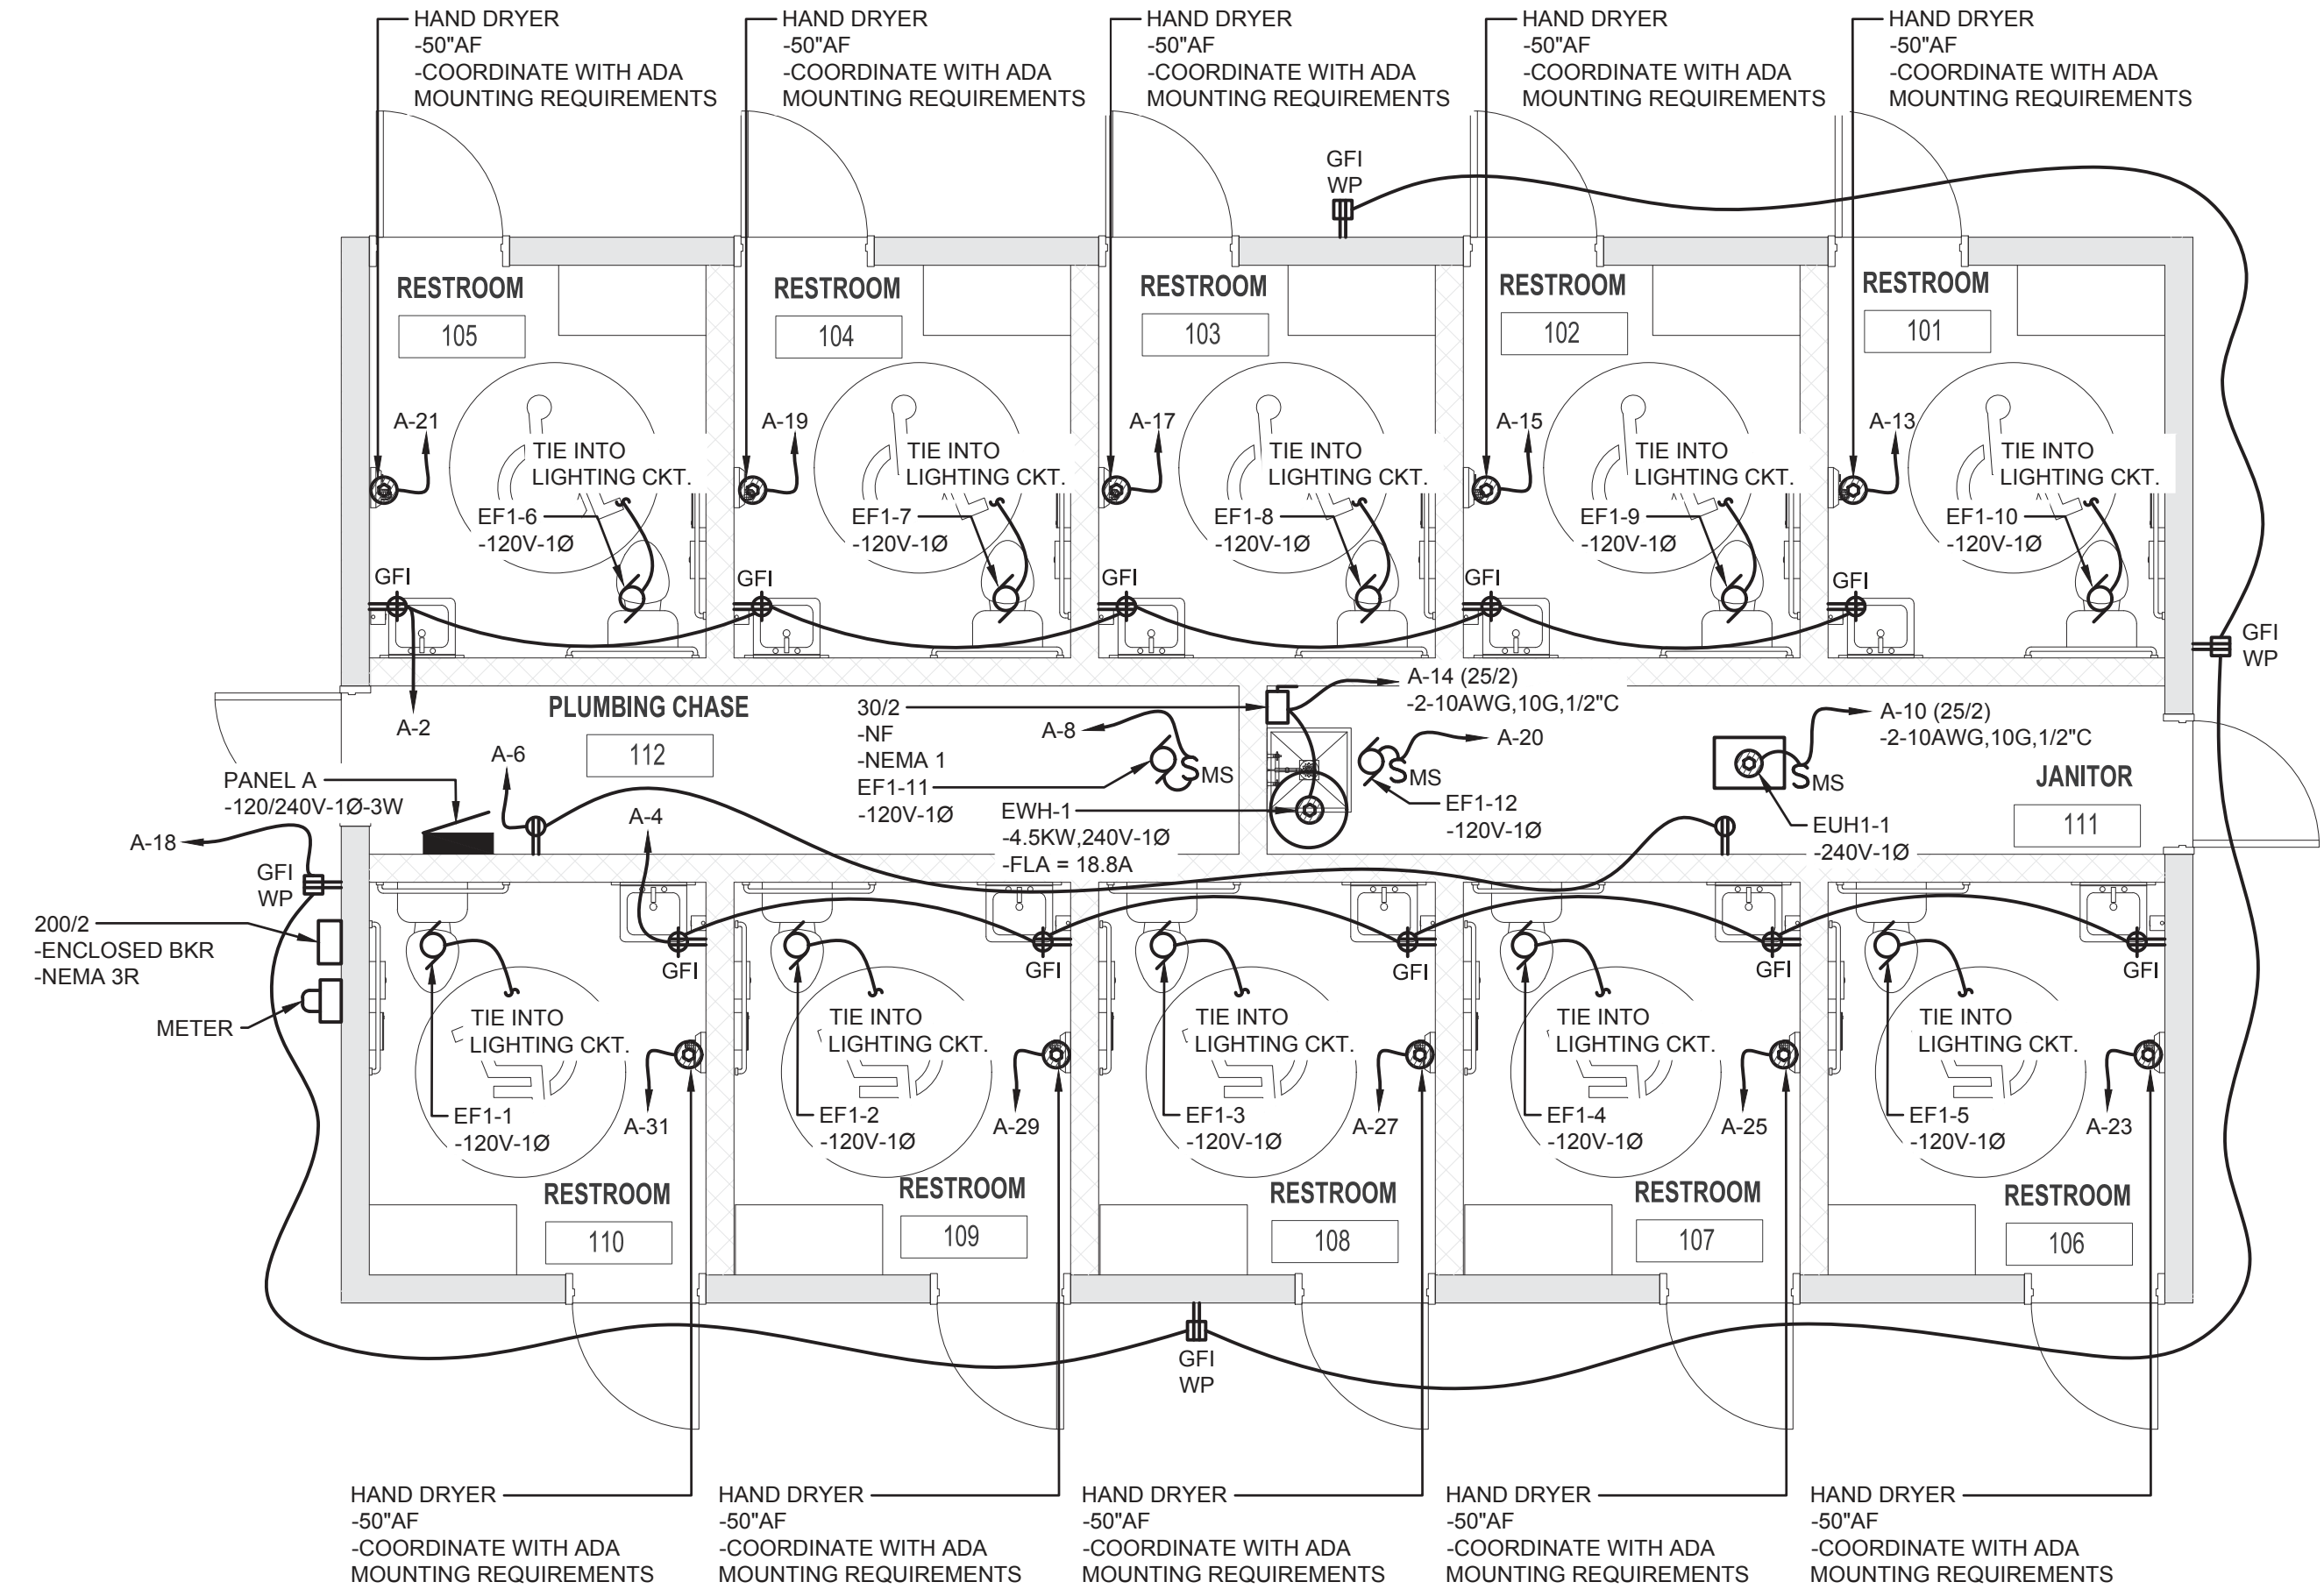

LIGHTING GENERAL NOTES:	
1	THE ELECTRICAL CONTRACTOR SHALL BECOME FAMILIAR WITH ALL OTHER CONTRACT DOCUMENTS, AND SHALL BE RESPONSIBLE FOR THE ELECTRICAL WORK REQUIRED BY THESE DOCUMENTS.
2	COORDINATE SWITCH BOX LOCATIONS WITH FURNITURE, CABINETS, DOORS, SIDE LITES, ETC.. IN GENERAL, SWITCHES SHALL BE ADJACENT TO LATCH SIDE OF DOOR. REFER TO ARCHITECTURAL ELEVATIONS.
3	COORDINATE ROUTING OF CONDUITS WITH OTHER TRADES. CONDUITS SHALL BE RUN PARALLEL AND PERPENDICULAR TO WALLS, CEILINGS, AND FLOORS. PROVIDE JUNCTION AND/OR PULL BOXES AS REQUIRED BY FIELD CONDITIONS.
4	PROVIDE IDENTIFICATION FOR EQUIPMENT, DEVICES & BRANCH CIRCUIT CONDUCTORS AS CALLED FOR IN THE SPECIFICATIONS.
5	REFER TO THE SYMBOLS LIST AND SPECIFICATIONS FOR MOUNTING HEIGHTS OF DEVICES.
6	REFER TO PROJECT SPECIFICATIONS FOR ADDITIONAL REQUIREMENTS, EQUIPMENT SCHEDULES AND DETAILS.
7	COORDINATE THE LOCATION OF LIGHTS, ETC. WITH OTHER TRADES. IN GENERAL, LIGHTS, ETC. SHALL BE MOUNTED IN THE CENTER OF A CEILING TILE. REFER TO ARCHITECTURAL REFLECTED CEILING PLAN.
8	CONTRACTOR SHALL PROVIDE STRUCTURAL SUPPORT AS REQUIRED TO INSTALL LIGHTING FIXTURES.
9	EMERGENCY AND NORMAL POWERED LIGHTING BRANCH CIRCUITS SHALL BE INSTALLED IN SEPARATE RACEWAY SYSTEMS PER NEC 700
10	WHERE THE CONTRACTOR DEVIATES FROM THIS SET OF CONSTRUCTION DOCUMENTS AND RESUBMISSION OF REVISED DRAWINGS IS REQUIRED BY THE PERMITTING OFFICE/OFFICIAL, A MINIMUM CHARGE OF \$750.00 PER AFFECTED DRAWING SHEET WILL BE BILLED TO THE CONTRACTOR. THE REVISED DRAWINGS WILL NOT BE PROVIDED AND/OR SUBMITTED TO THE PERMIT OFFICE UNTIL A PURCHASE ORDER OR SIGNED AGREEMENT IS ISSUED BY THE CONTRACTOR TO THE DESIGN PROFESSIONAL FOR WORK REQUIRED. THIS SHALL NOT APPLY TO UNFORESEEN CONDITIONS OR CHANGES REQUIRED FOR THE PROJECT THAT ARE NOT INITIATED BY THE CONTRACTOR.

THIS ITEM HAS BEEN ELECTRONICALLY SIGNED AND SEALED BY THE ENGINEER INDICATED HEREIN WITH THE DATE AND INDICATED IN THE TIME STAMP USING AN RSA CODE. PRINTED COPIES OF THIS DOCUMENT ARE NOT CONSIDERED SIGNED AND SEALED AND THE SIGN AUTHENTICATION CODE MUST BE VERIFIED ON ANY ELECTRONIC COPIES.

DESIGNER :	BCP	ISSUE DATE:	28 MARCH 2023	SYMBOL	REVISION	DATE
DRAWN BY:	BCP	COMP. FILE No.:	18180	SYMBOL	REVISION	DATE
REVIEWED BY:	RJL	STATE PROJECT No.:	61383C	SYMBOL	REVISION	DATE
Consultant : TOMAHAWK ENGINEERING & CONSULTING, INC.						
1940 Buford Blvd. - Tallahassee, FL 32302 Phone: 850-402-3040, Fax: 850-402-9699 Certificate of Authorization #: 29709 Tallahassee Project #: 22033						
Department of Environmental Protection Office of Operations Bureau of Design and Construction 3800 Commonwealth Blvd., Tallahassee, FL 32399 (850) 425-2300						
FLOOR PLANS - ELECTRICAL						
PROJECT TITLE ICHETUCKNEE SPRINGS STATE PARK REPLACE RESTROOM						
SHEET NO. E101						

100% CONTRACT DOCUMENTS

PANEL: A

FED FROM: UTILITY SERVICE E.B.

MOUNTING: SURFACE

ENCLOSURE: NEMA 1

VOLTAGE: 120/240V-1PH-3W

BRANCH: NORMAL

A/C RATING: 10,000A

MAINS: 200A MLO

CKT. NO.	BKR.	DESCRIPTION	LEG A	LEG B	DESCRIPTION	BKR.	CKT. NO.
1	20/1	LTS. EXTERIOR	160 900		REC. RR. 101-105	20/1	2
3	20/1	LTS. INTERIOR/EX. FAN RR 104,105,112		1131 900	REC. RR. 106-110	20/1	4
5	20/1	LTS. INTERIOR/EX. FAN RR 102,103,111	1131 360		REC. JAN. 111,CHASE 112	20/1	6
7	20/1	LTS. INTERIOR/EX. FAN RR 101,106		1106 250	EF1-11 CHASE 112	15/1	8
9	20/1	LTS. INTERIOR/EX. FAN RR 107,108	1106 1500		EUH1-1	25/2	10
11	20/1	LTS. INTERIOR/EX. FAN RR 109,110		1106 1500	----	---	12
13	*20/1	HAND DRYER RR 101	1100 2250		EW-H-1	25/2	14
15	*20/1	HAND DRYER RR 102		1100 2250	----	---	16
17	*20/1	HAND DRYER RR 103	1100 720		REC. EXTERIOR	20/1	18
19	*20/1	HAND DRYER RR 104		1100 250	EF1-12 JAN. 111	15/1	20
21	*20/1	HAND DRYER RR 105	1100		SPARE	20/1	22
23	*20/1	HAND DRYER RR 106		1100	SPARE	20/1	24
25	*20/1	HAND DRYER RR 107	1100		SPARE	20/1	26
27	*20/1	HAND DRYER RR 108		1100	SPARE	20/1	28
29	*20/1	HAND DRYER RR 109	1100		SPARE	20/1	30
31	*20/1	HAND DRYER RR 110		1100	SPARE	20/1	32
33	20/1	SPARE			SPARE	20/1	34
35	20/1	SPARE			SPARE	20/1	36
37	15/2	SPD	5356		PANEL P	60/2	38
39	---	---		5176	----	---	40
			18983	19169			

NOTES:

1. BASIS OF DESIGN IS A SQUARE D NQOD WITH BOLT ON QO BREAKERS.


2. *PROVIDE GFCI TYPE BREAKER.

2. PROVIDE TYPE 1 EXTERNALLY MOUNTED SPD.

	CONNECTED LOADS		DEMAND LOADS	
	VA	AMPS	VA	AMPS
LIGHTING	5740	24	5740	24
RECEPTACLES	3060	13	3060	13
MOTORS	22852	95	22852	95
MISCELLANEOUS	6500	27	6500	27
TOTAL (AVERAGE PER PHASE)	38152	159	38152	159
MINIMUM OVERCURRENT PROTECTION (125% OF TOTAL DEMAND LOAD) =				
199				

PANEL: P				VOLTAGE: 120/240V-1PH-3W					
FED FROM: PANEL A				BRANCH: NORMAL					
MOUNTING: SURFACE				A/C RATING: 10,000A					
ENCLOSURE: NEMA 3R				MAINS: 100A MLO					
CKT. NO.	BKR.	DESCRIPTION	LEG A		LEG B		DESCRIPTION	BKR.	CKT. NO.
1	15/2	LIFT STATION PUMP #1	876	336			TREATMENT PLANT BLOWER #1	15/2	2
3	---	---			876	336	---	---	4
5	15/2	LIFT STATION PUMP #2	876	336			TREATMENT PLANT BLOWER #2	15/2	6
7	---	---			876	336	---	---	8
9	15/2	LIFT STATION CONTROLS & ALARM	500	876			DRAINFIELD DOSING PUMP #1	15/2	10
11	---	---			500	876	---	---	12
13	15/2	TREATMENT PLANT CONTROLS & ALARM	500	876			DRAINFIELD DOSING PUMP #2	15/2	14
15	---	---			500	876	---	---	16
17	20/1	REC. EXTERIOR	180				SPACE		18
19		SPACE					SPACE		20
21		SPACE					SPACE		22
23		SPACE					SPACE		24
25		SPACE					SPACE		26
27		SPACE					SPACE		28
29		SPACE					SPACE		30
			5356		5176				
NOTES:									
1. BASIS OF DESIGN IS A SQUARE D NQOD WITH BOLT ON QO BREAKERS.									
CONNECTED LOADS									
VA AMPS									
LIGHTING 0 0									
RECEPTACLES 180 1									
MOTORS 8352 35									
MISCELLANEOUS 2000 8									
TOTAL (AVERAGE PER PHASE) 10532 44									
MINIMUM OVERCURRENT PROTECTION (125% OF TOTAL DEMAND LOAD) =									
DEMAND LOADS									
VA AMPS									
LIGHTING 0 0									
RECEPTACLES 180 1									
MOTORS 8352 35									
MISCELLANEOUS 2000 8									
TOTAL (AVERAGE PER PHASE) 10532 44									
55									

THIS ITEM HAS BEEN ELECTRONICALLY SIGNED AND SEALED BY THE ENGINEER INDICATED HEREIN WITH THE DATE AS INDICATED IN THE TIME STAMP USING AN RSA CODE.
PRINTED COPIES OF THIS DOCUMENT ARE NOT CONSIDERED SIGNED AND SEALED AND THE SIGN AUTHENTICATION CODE MUST BE VERIFIED ON ANY ELECTRONIC COPIES.

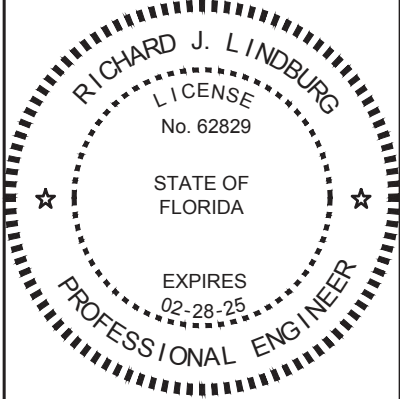

ICHELUCKNEE SPRINGS STATE PARK
12087 SOUTHWEST U.S. 27, FORT WHITE, FL 32038

PANEL SCHEDULES - ELECTRICAL

ICHELUCKNEE SPRINGS STATE PARK
REPLACE RESTROOM

SHEET NO.

E701

SYMBOL	REVISION	DATE	SYMBOL	REVISION	DATE
1			3		
2			4		
TOMAHAWK ENGINEERING & CONSULTING, INC. 1940 Buford Blvd. - Tallahassee, FL 32302 Phone: 850-402-3040, Fax: 850-402-9689 Certificate of Authorization #: 29709 Tallahaw Project #: 22033					
Department of Environmental Protection Office of Operations Bureau of Design and Construction 3800 Commonwealth Blvd., Tallahassee, FL 32399 (850) 425-2300					