



*** PROPOSED PARTIAL *
FRONT ELEVATION ***

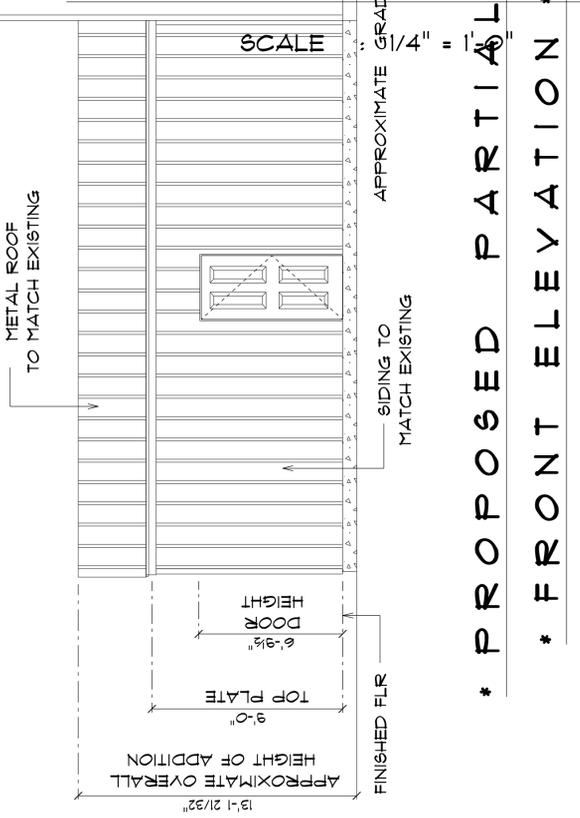


*** PROPOSED PARTIAL *
* FRONT ELEVATION *
SCALE : 1/4" = 1'-0"**

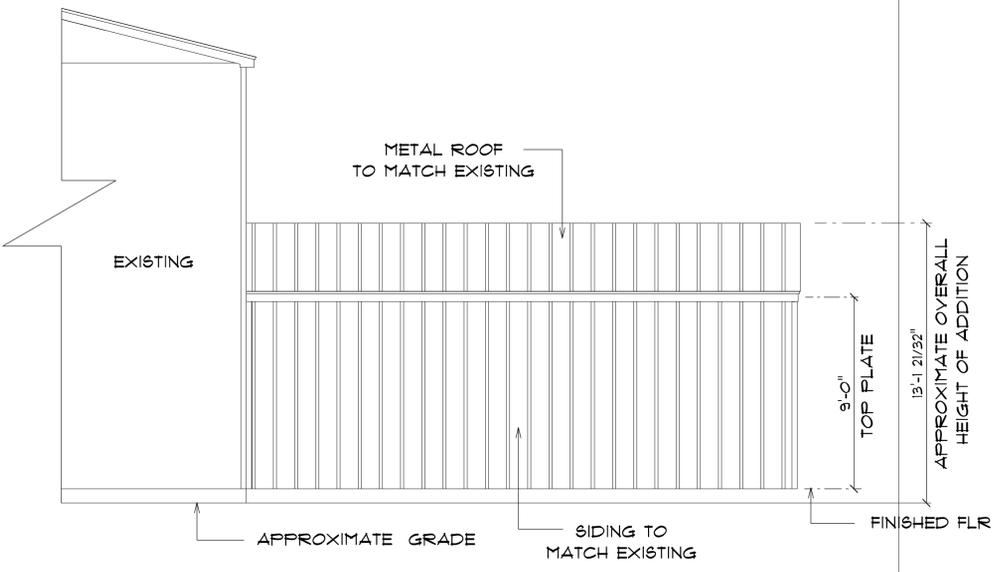

*** PROPOSED PARTIAL *
* REAR ELEVATION ***

SCALE : 1/4" = 1'-0"

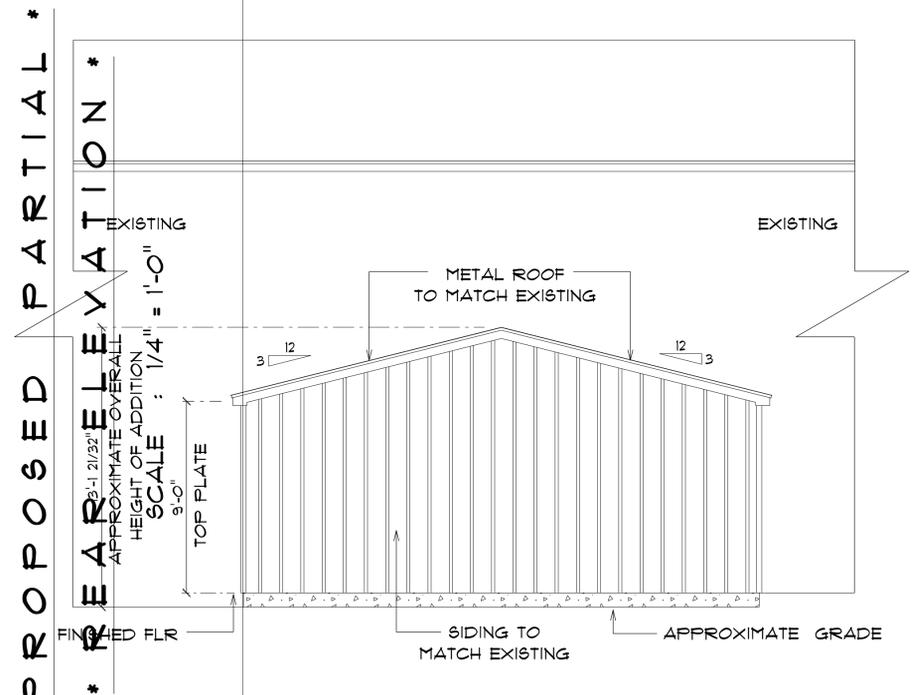

*** PROPOSED PARTIAL *
* REAR ELEVATION *
* PROPOSED PARTIAL *
* LEFT ELEVATION ***

SCALE : 1/4" = 1'-0"

IMPORTANT NOTE:
THIS ITEM HAS BEEN DIGITALLY SIGNED AND SEALED BY CAROL CHADWICK, P.E. ON THE DATE ADJACENT TO THE SEAL. PRINTED COPIES OF THIS DOCUMENT ARE NOT CONSIDERED SIGNED & SEALED AND THE SIGNATURE MUST BE VERIFIED ON ANY ELECTRONIC COPIES.

H&S COMMERCIAL

Carol Chadwick, P.E.
1208 SW Fairfax Glen
Lake City, Florida, 32025
Cell: (307) 680 - 1172
Email: ccpeywo@gmail.com

PRINTED DATE: Friday, September 5, 2025	
DRAWN BY: Daniel Hammond	CHECKED BY: THR
BUILDING CONTRACTOR:	
FINALS DATE:	
JOB NUMBER:	
DRAWING NUMBER A-3	
OF 4 SHEETS	

ELECT	
ELECT	
dimmer sw	
electrical	
outlet 220v	
outlet do	
outlet gfi	
pot light	
switch 3 w	

ELECTRICAL PLAN NOTES

E-1 WIRE ALL APPLIANCES, HYAC UNITS AND OTHER EQUIPMENT PER MANUFACTURERS SPECIFICATIONS.

E-2 CONSULT THE OWNER FOR THE NUMBER OF SEPERATE TELEPHONE LINES TO BE INSTALLED.

E-3 ALL INSTALLATIONS SHALL BE PER NATIONAL ELECTRIC CODE.

E-4 ALL SMOKE DETECTORS SHALL BE 120V W/BATTERY BACKUP OF THE PHOTOELECTRIC TYPE, AND SHALL BE INTERLOCKED TOGETHER. INSTALL INSIDE AND NEAR ALL BEDROOMS.

E-5 TELEPHONE, TELEVISION AND OTHER LOW VOLTAGE DEVICES OR OUTLETS SHALL BE AS PER THE OWNERS DIRECTION AND IN ACCORDANCE WITH APPLICABLE SECTIONS OF NATIONAL ELCT. CODE LATEST EDITION.

E-6 ELECTRICAL CONTRACTOR SHALL BE RESPONSIBLE FOR THE DESIGN AND SIZING OF ELECTRICAL SERVICE AND CIRCUITS.


E-7 ENTRY OF SERVICE (UNDERGROUND OR OVERHEAD) IS TO BE DETERMINED BY THE POWER COMPANY.

E-8 * ALL BEDROOM RECEPTICALS ARE TO BE AFCI (ARC FAULT CIRCUIT INTERRUPT)

ELECTRICAL LEGEND		
ELECTRICAL	COUNT	SYMBOL
dimmer switch 3-way	2	\$3D
electrical panel	1	[Symbol]
outlet 220v	2	[Symbol]
outlet double	11	[Symbol]
outlet gfi	2	[Symbol]
pot light	16	[Symbol]
switch 3 way	2	\$3

ELECTRICAL PLAN NOTES

- E-1 WIRE ALL APPLIANCES, HYAC UNITS AND OTHER EQUIPMENT PER MANUFACTURERS SPECIFICATIONS.
- E-2 CONSULT THE OWNER FOR THE NUMBER OF SEPERATE TELEPHONE LINES TO BE INSTALLED.
- E-3 ALL INSTALLATIONS SHALL BE PER NATIONAL ELECTRIC CODE.
- E-4 ALL SMOKE DETECTORS SHALL BE 120V W/BATTERY BACKUP OF THE PHOTOELECTRIC TYPE, AND SHALL BE INTERLOCKED TOGETHER. INSTALL INSIDE AND NEAR ALL BEDROOMS.
- E-5 TELEPHONE, TELEVISION AND OTHER LOW VOLTAGE DEVICES OR OUTLETS SHALL BE AS PER THE OWNERS DIRECTION AND IN ACCORDANCE WITH APPLICABLE SECTIONS OF NATIONAL ELCT. CODE LATEST EDITION.
- E-6 ELECTRICAL CONTRACTOR SHALL BE RESPONSIBLE FOR THE DESIGN AND SIZING OF ELECTRICAL SERVICE AND CIRCUITS.
- E-7 ENTRY OF SERVICE (UNDERGROUND OR OVERHEAD) IS TO BE DETERMINED BY THE POWER COMPANY.
- E-8 * ALL BEDROOM RECEPTICALS ARE TO BE AFCI (ARC FAULT CIRCUIT INTERRUPT)

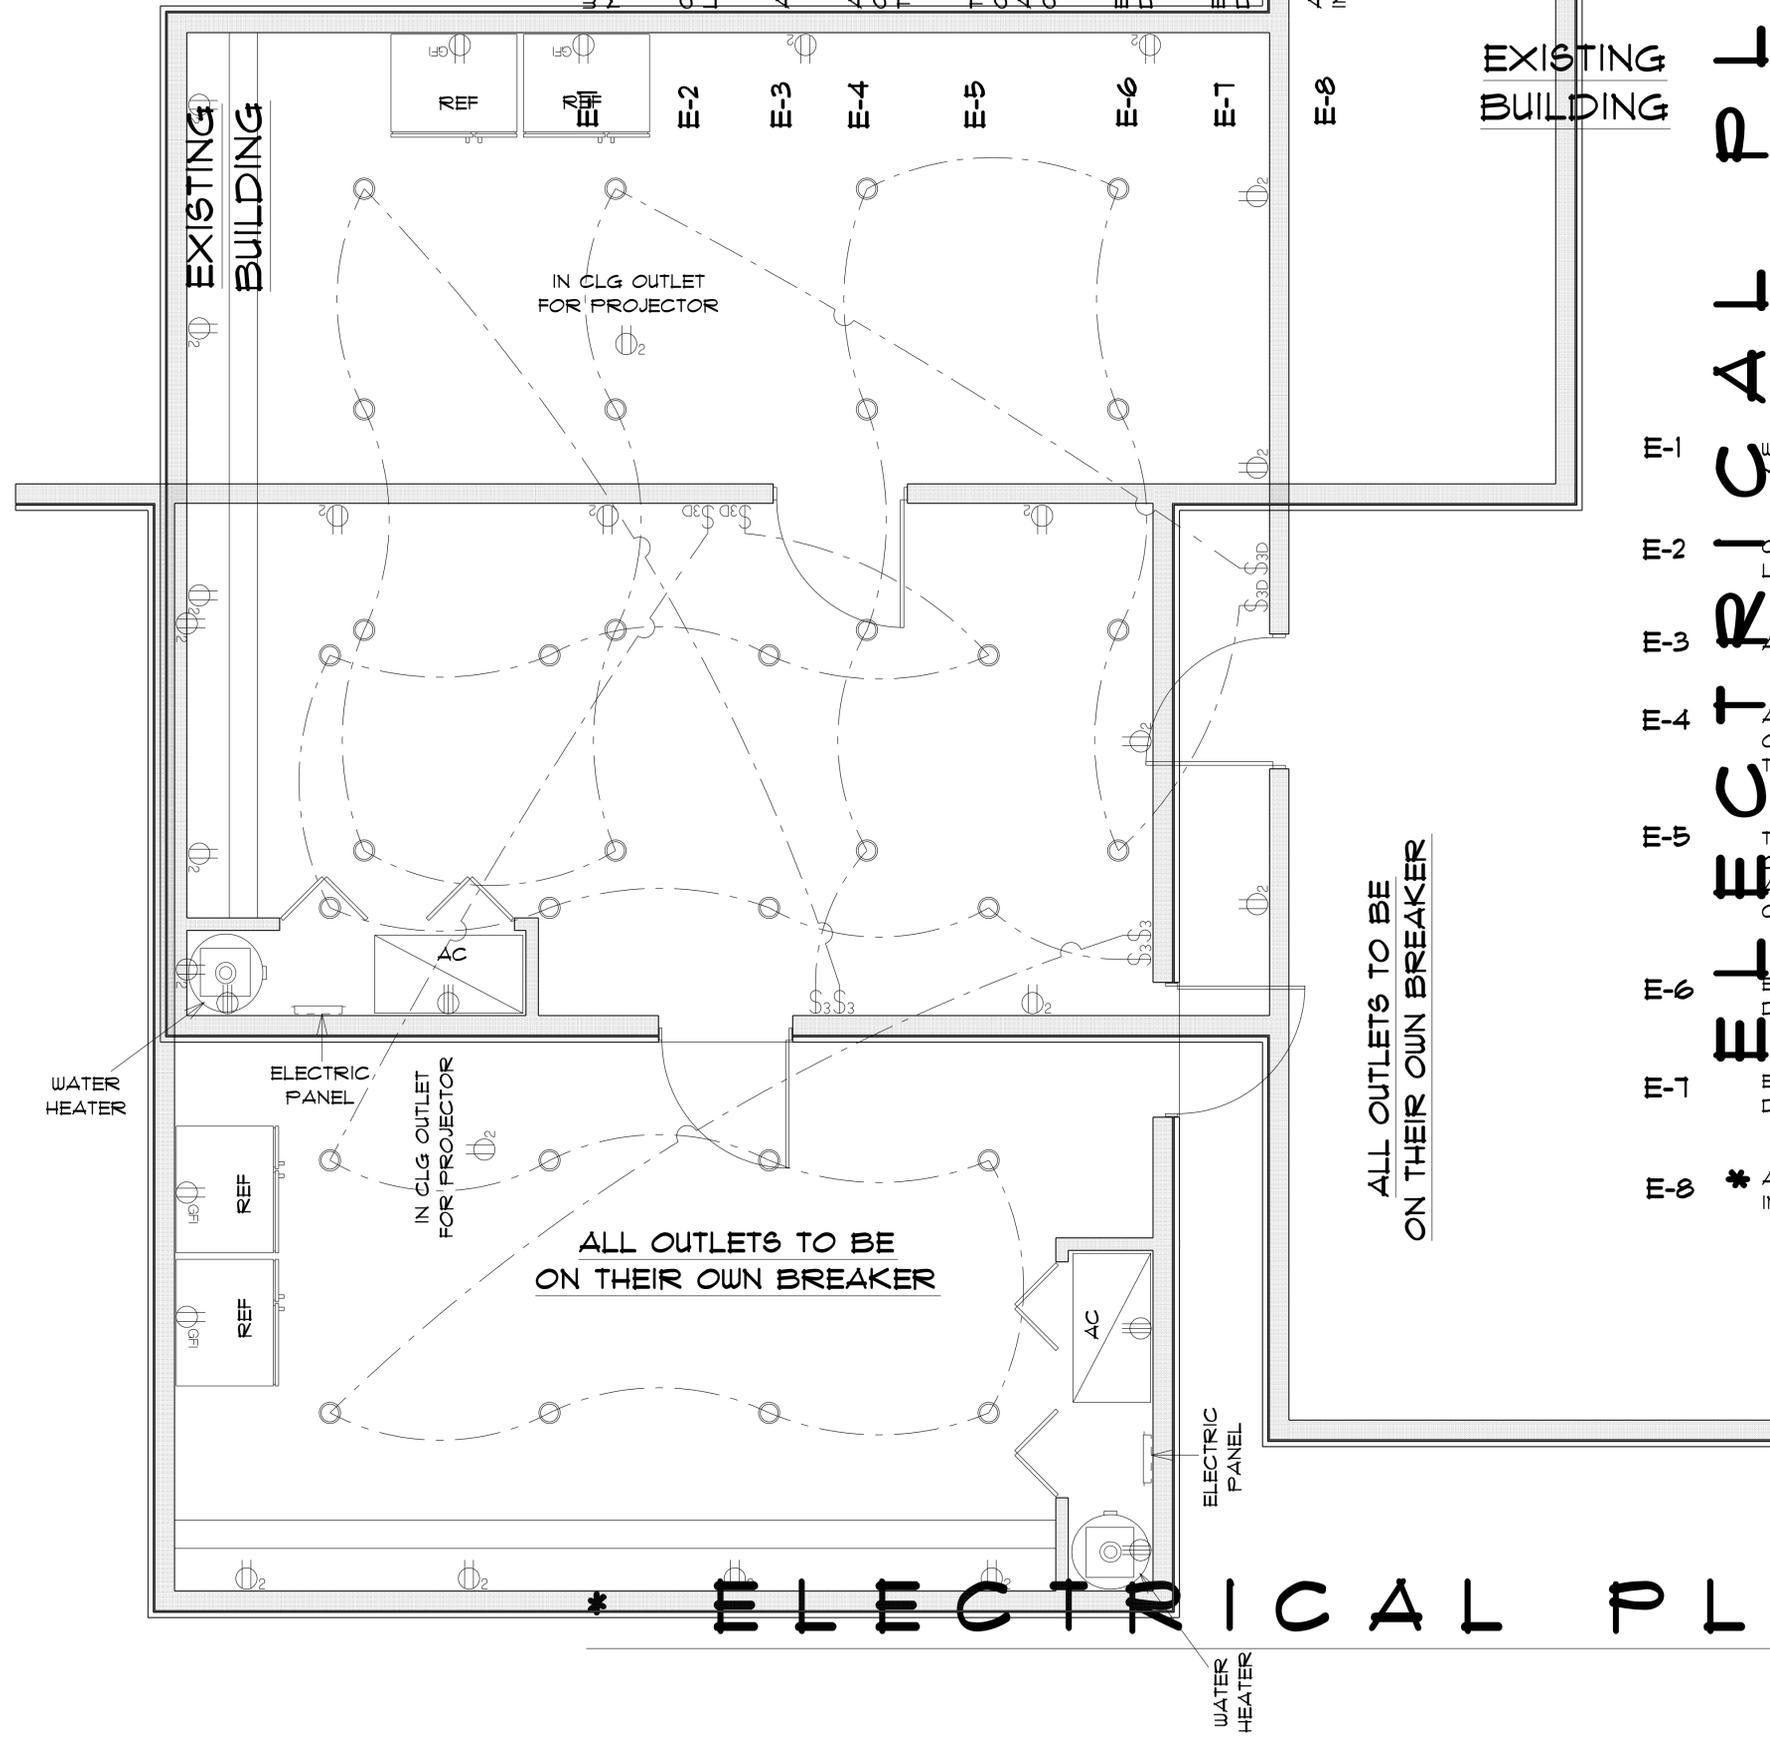

ELECTRICAL PLAN *

IMPORTANT NOTE:
 THIS ITEM HAS BEEN DIGITALLY SIGNED AND SEALED BY CAROL CHADWICK, P.E. ON THE DATE ADJACENT TO THE SEAL. PRINTED COPIES OF THIS DOCUMENT ARE NOT CONSIDERED SIGNED & SEALED AND THE SIGNATURE MUST BE VERIFIED ON ANY ELECTRONIC COPIES.

H46 COMMERCIAL

Carol Chadwick, P.E.
 1208 SW Fairfax Glen
 Lake City, Florida, 32025
 Cell: (307) 680 - 1172
 Email: ccpewyo@gmail.com

PRINTED DATE: Friday, September 5, 2025	
DRAWN BY: Daniel Hammond	CHECKED BY: THR
BUILDING CONTRACTOR:	
FINALS DATE:	
JOB NUMBER:	
DRAWING NUMBER A-4	
OF 4 SHEETS	